

 


CENTER PIER DETAIL
SCALE: 3/4"=1'-0"



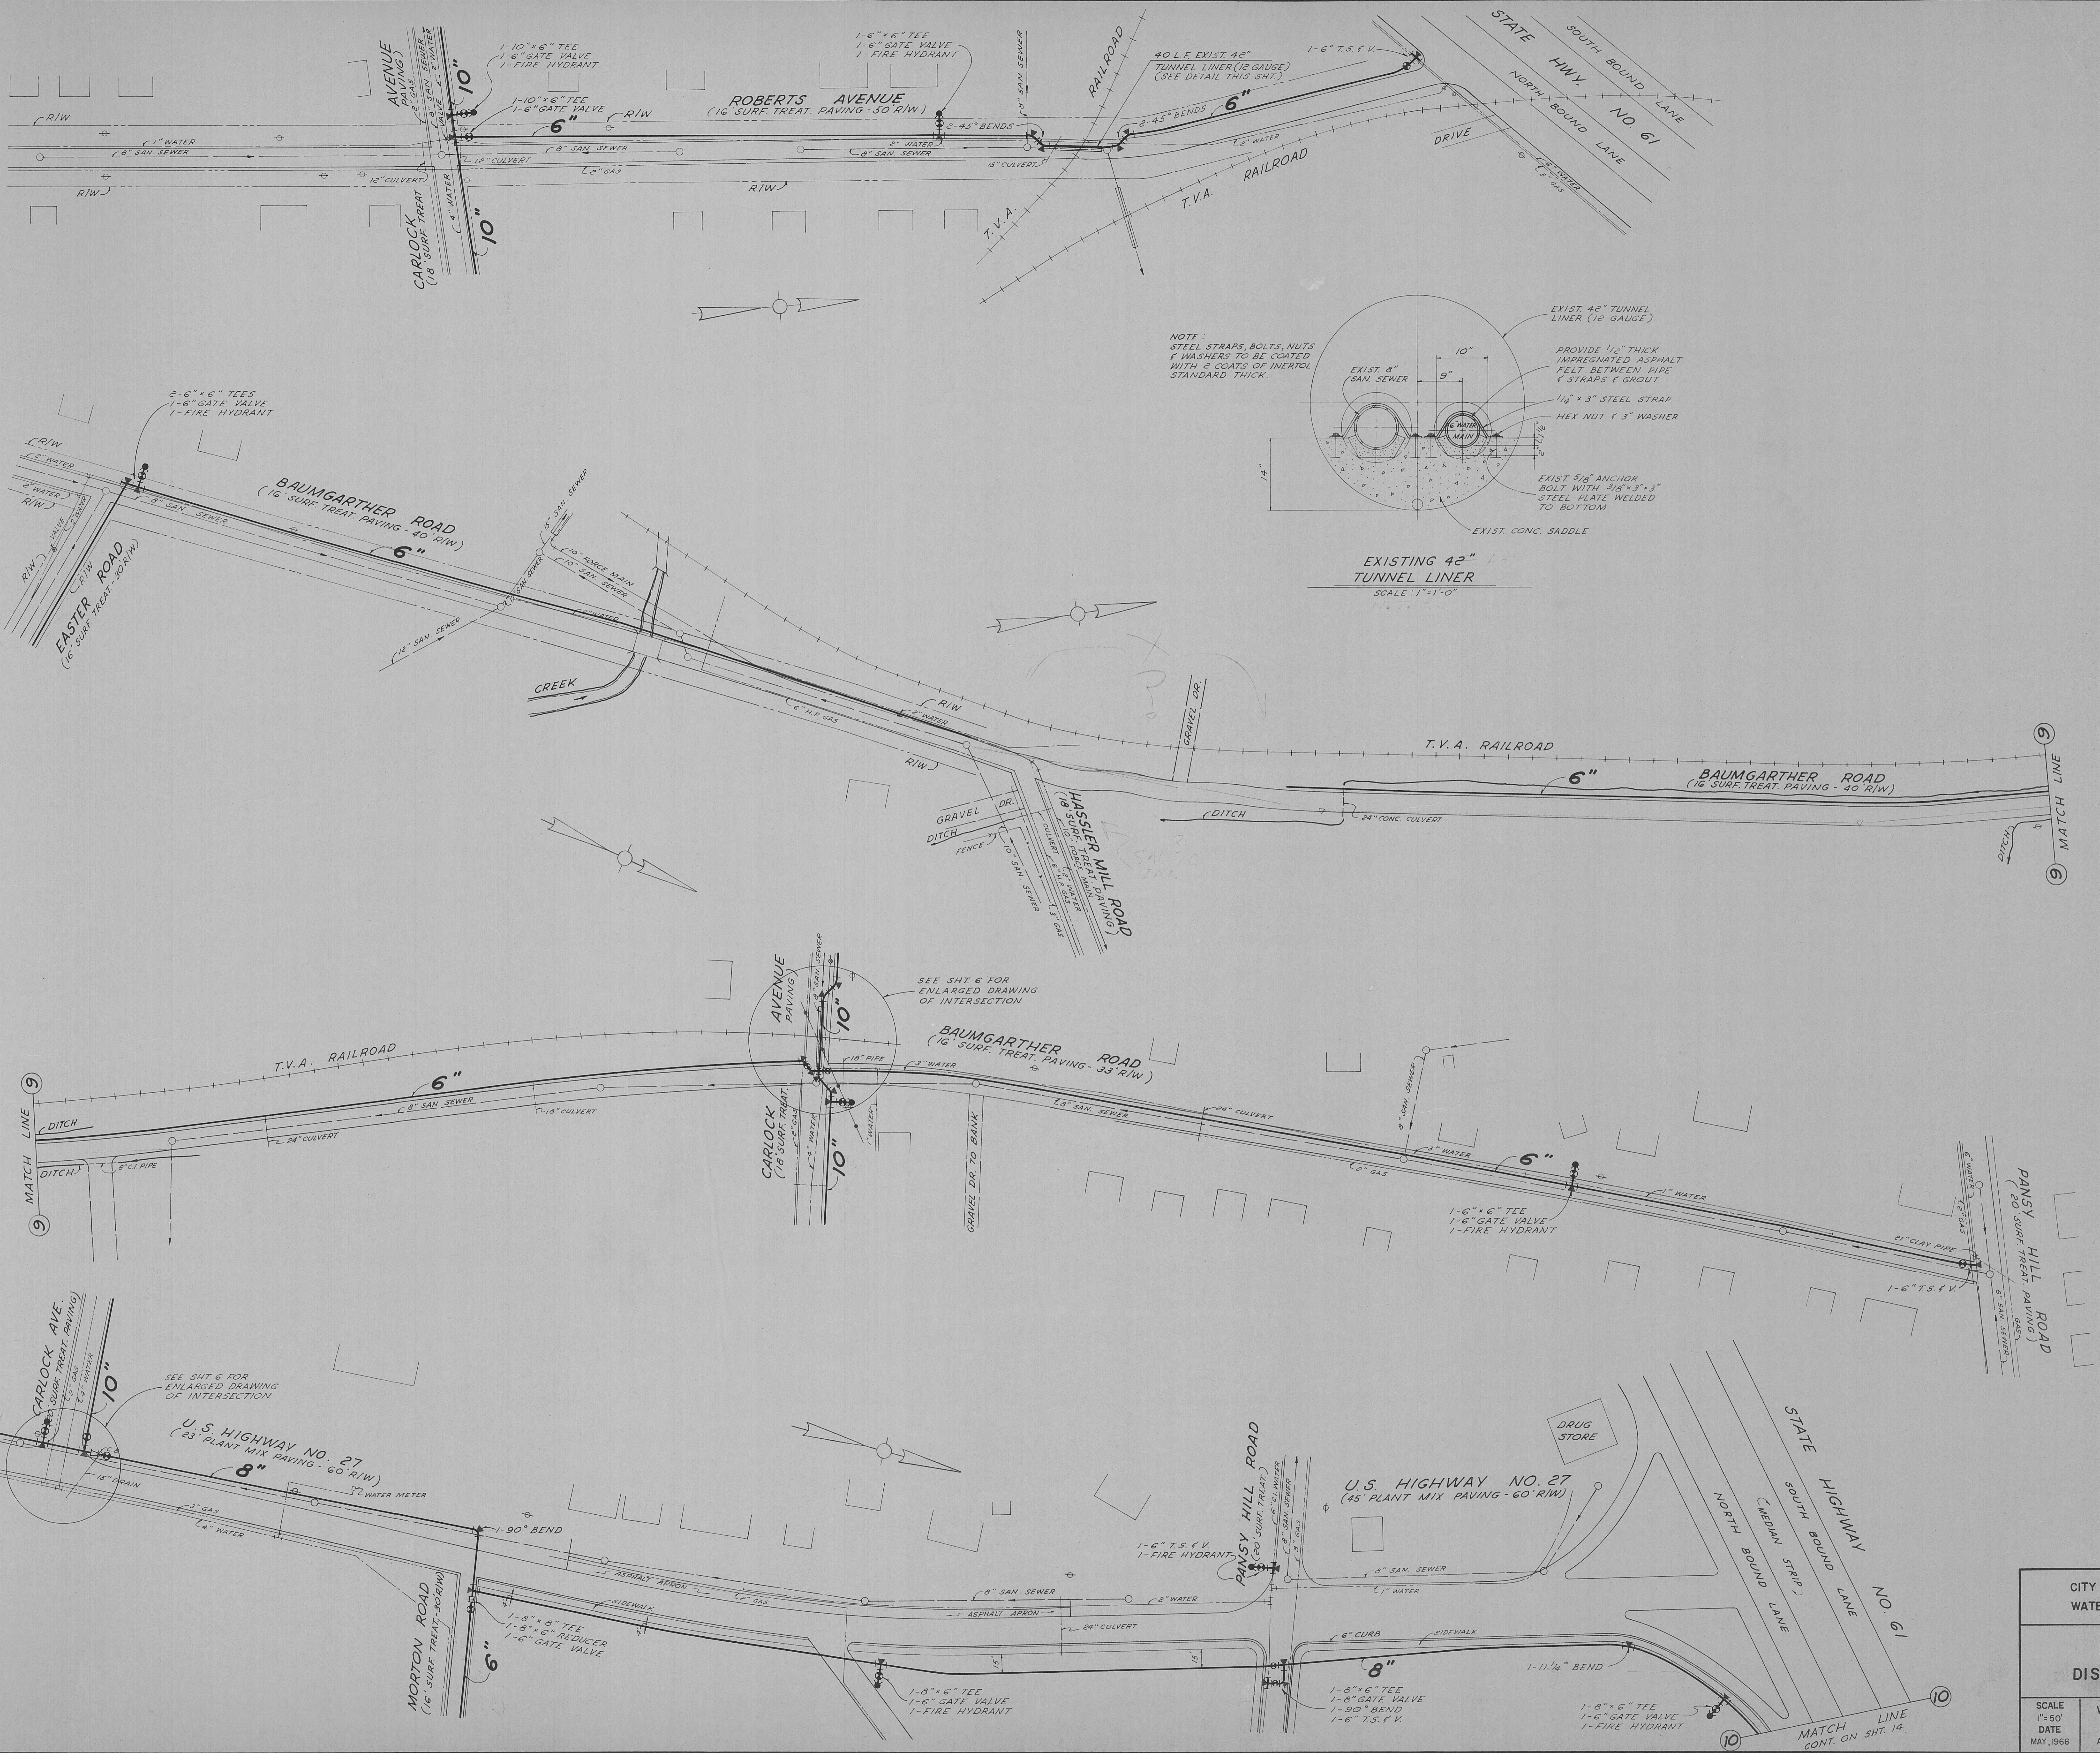

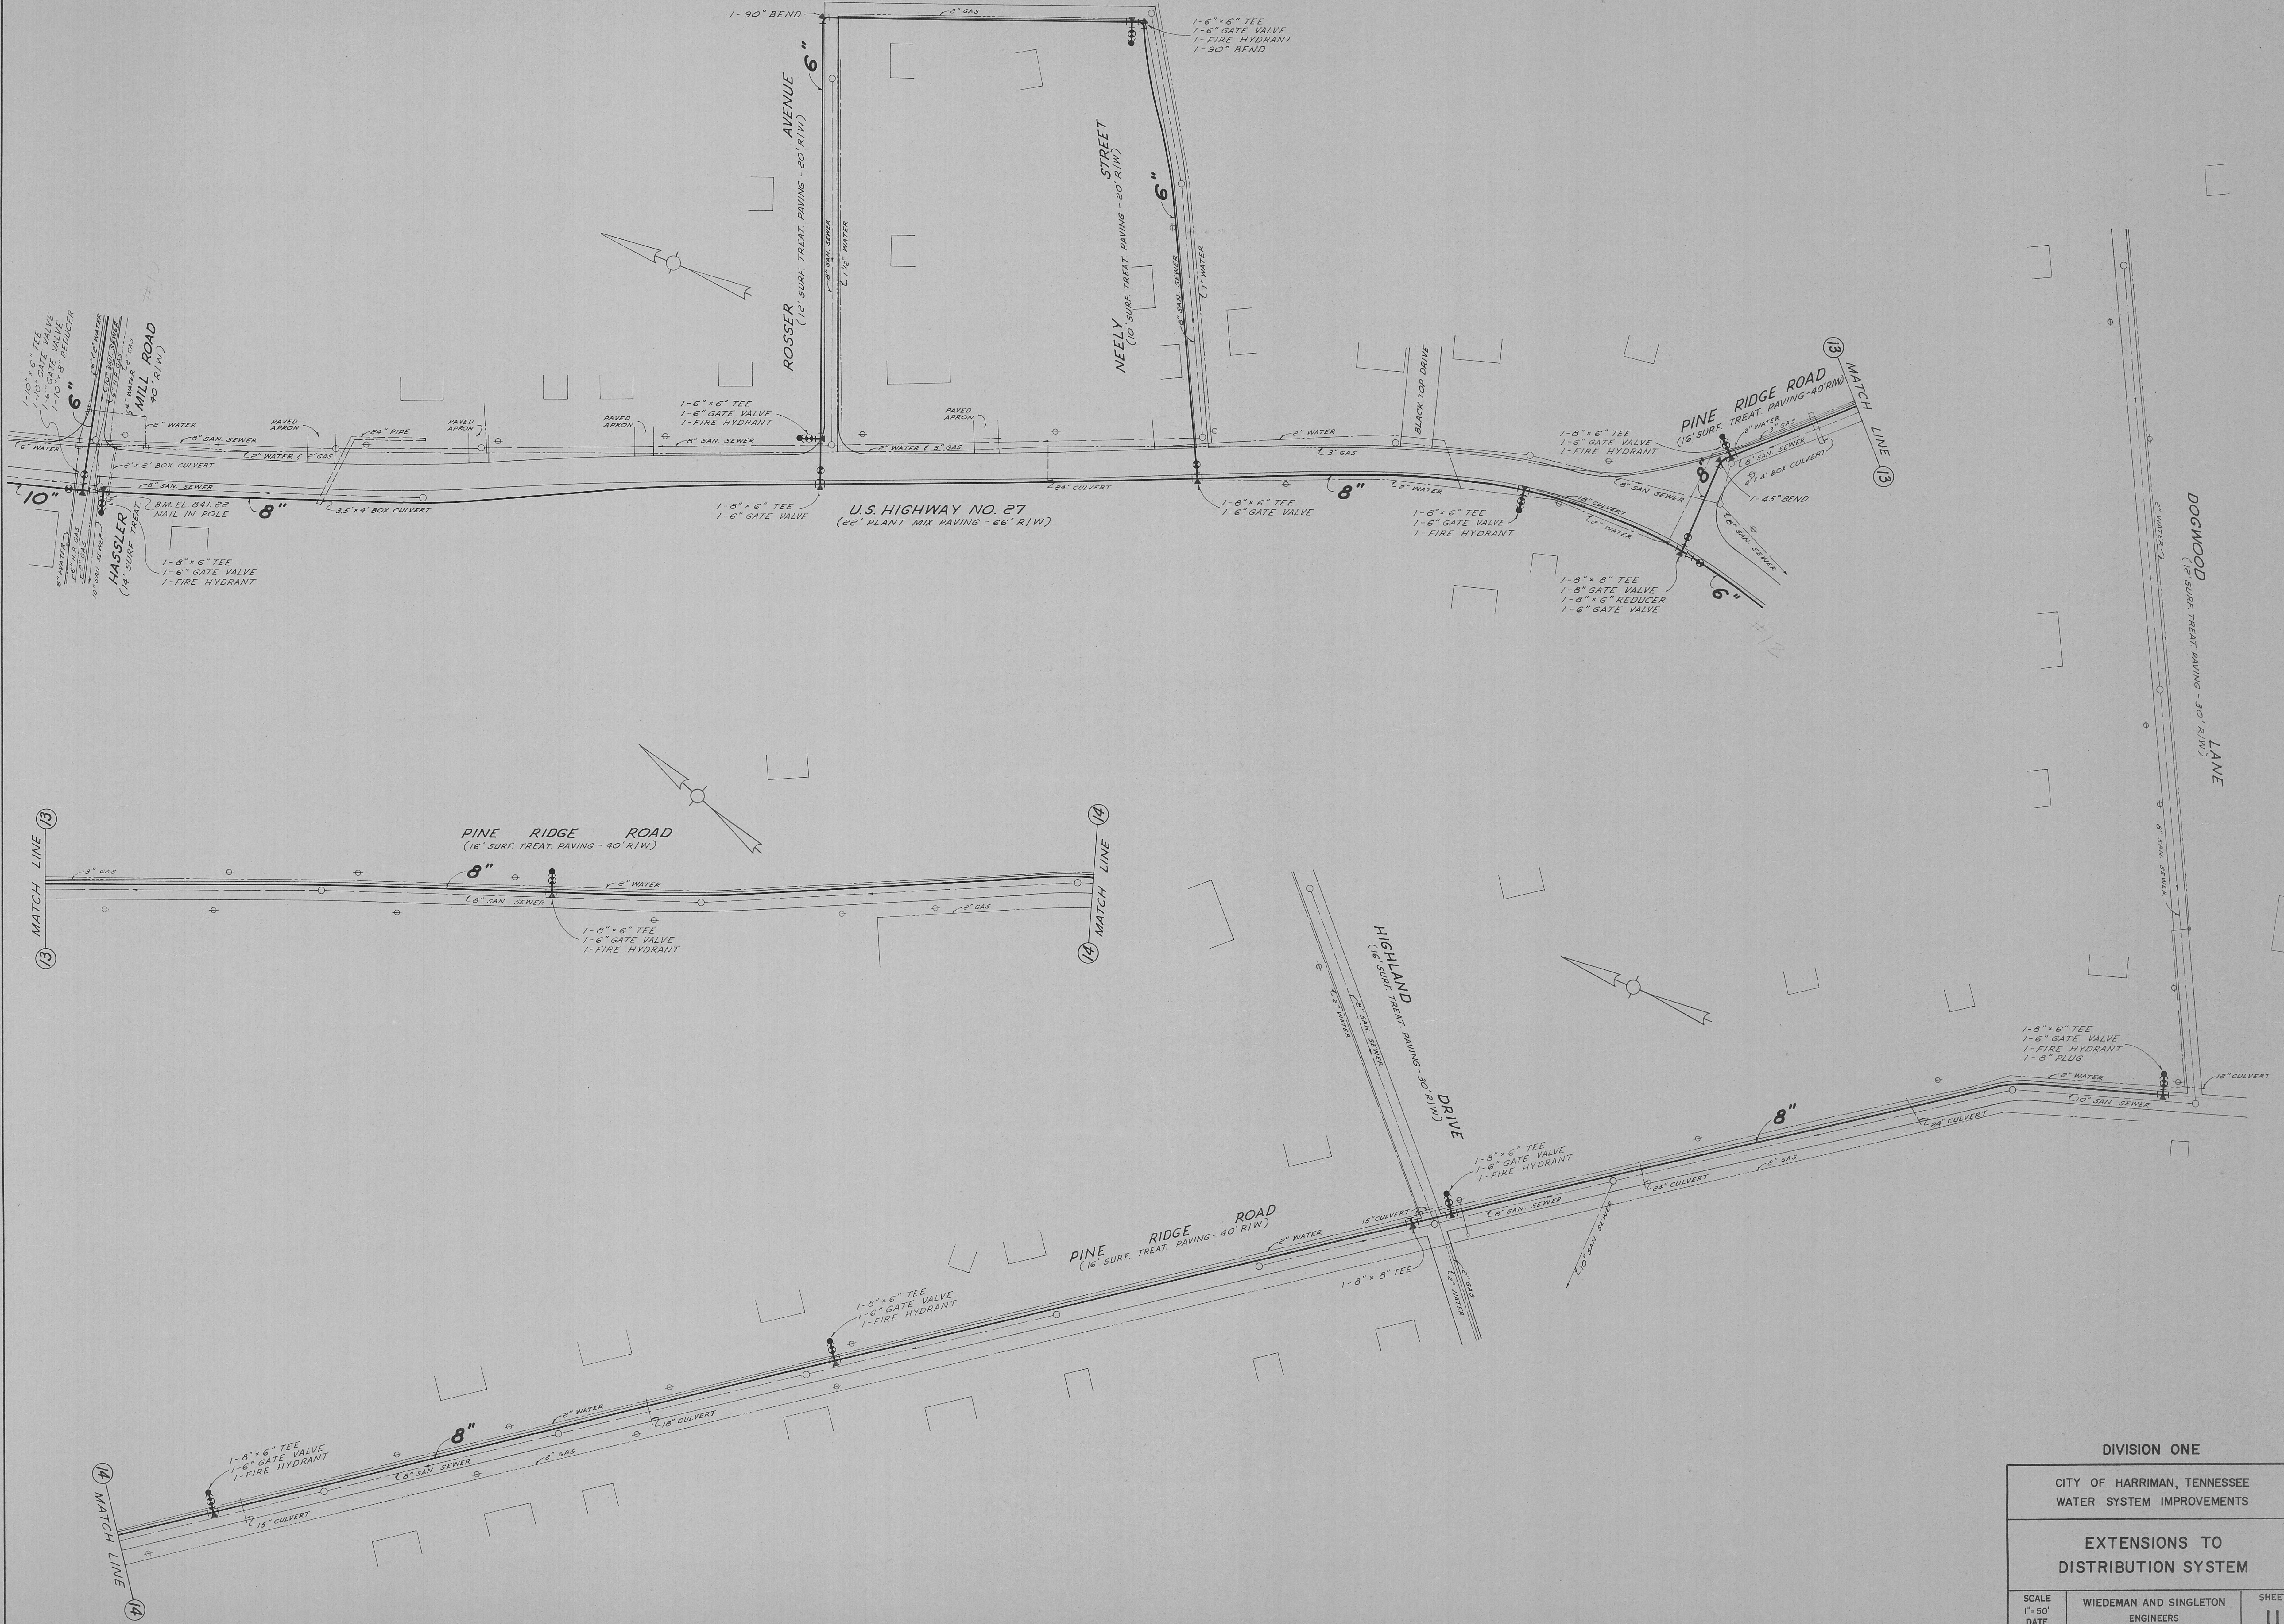






DIVISION ONE

CITY OF HARRIMAN, TENNESSEE
WATER SYSTEM IMPROVEMENTS

EXTENSIONS TO
DISTRIBUTION SYSTEM


SCALE
1"=50'
DATE
MAY, 1966
WIEDEMAN AND SINGLETON
ENGINEERS
ATLANTA, GEORGIA


13
OF 23

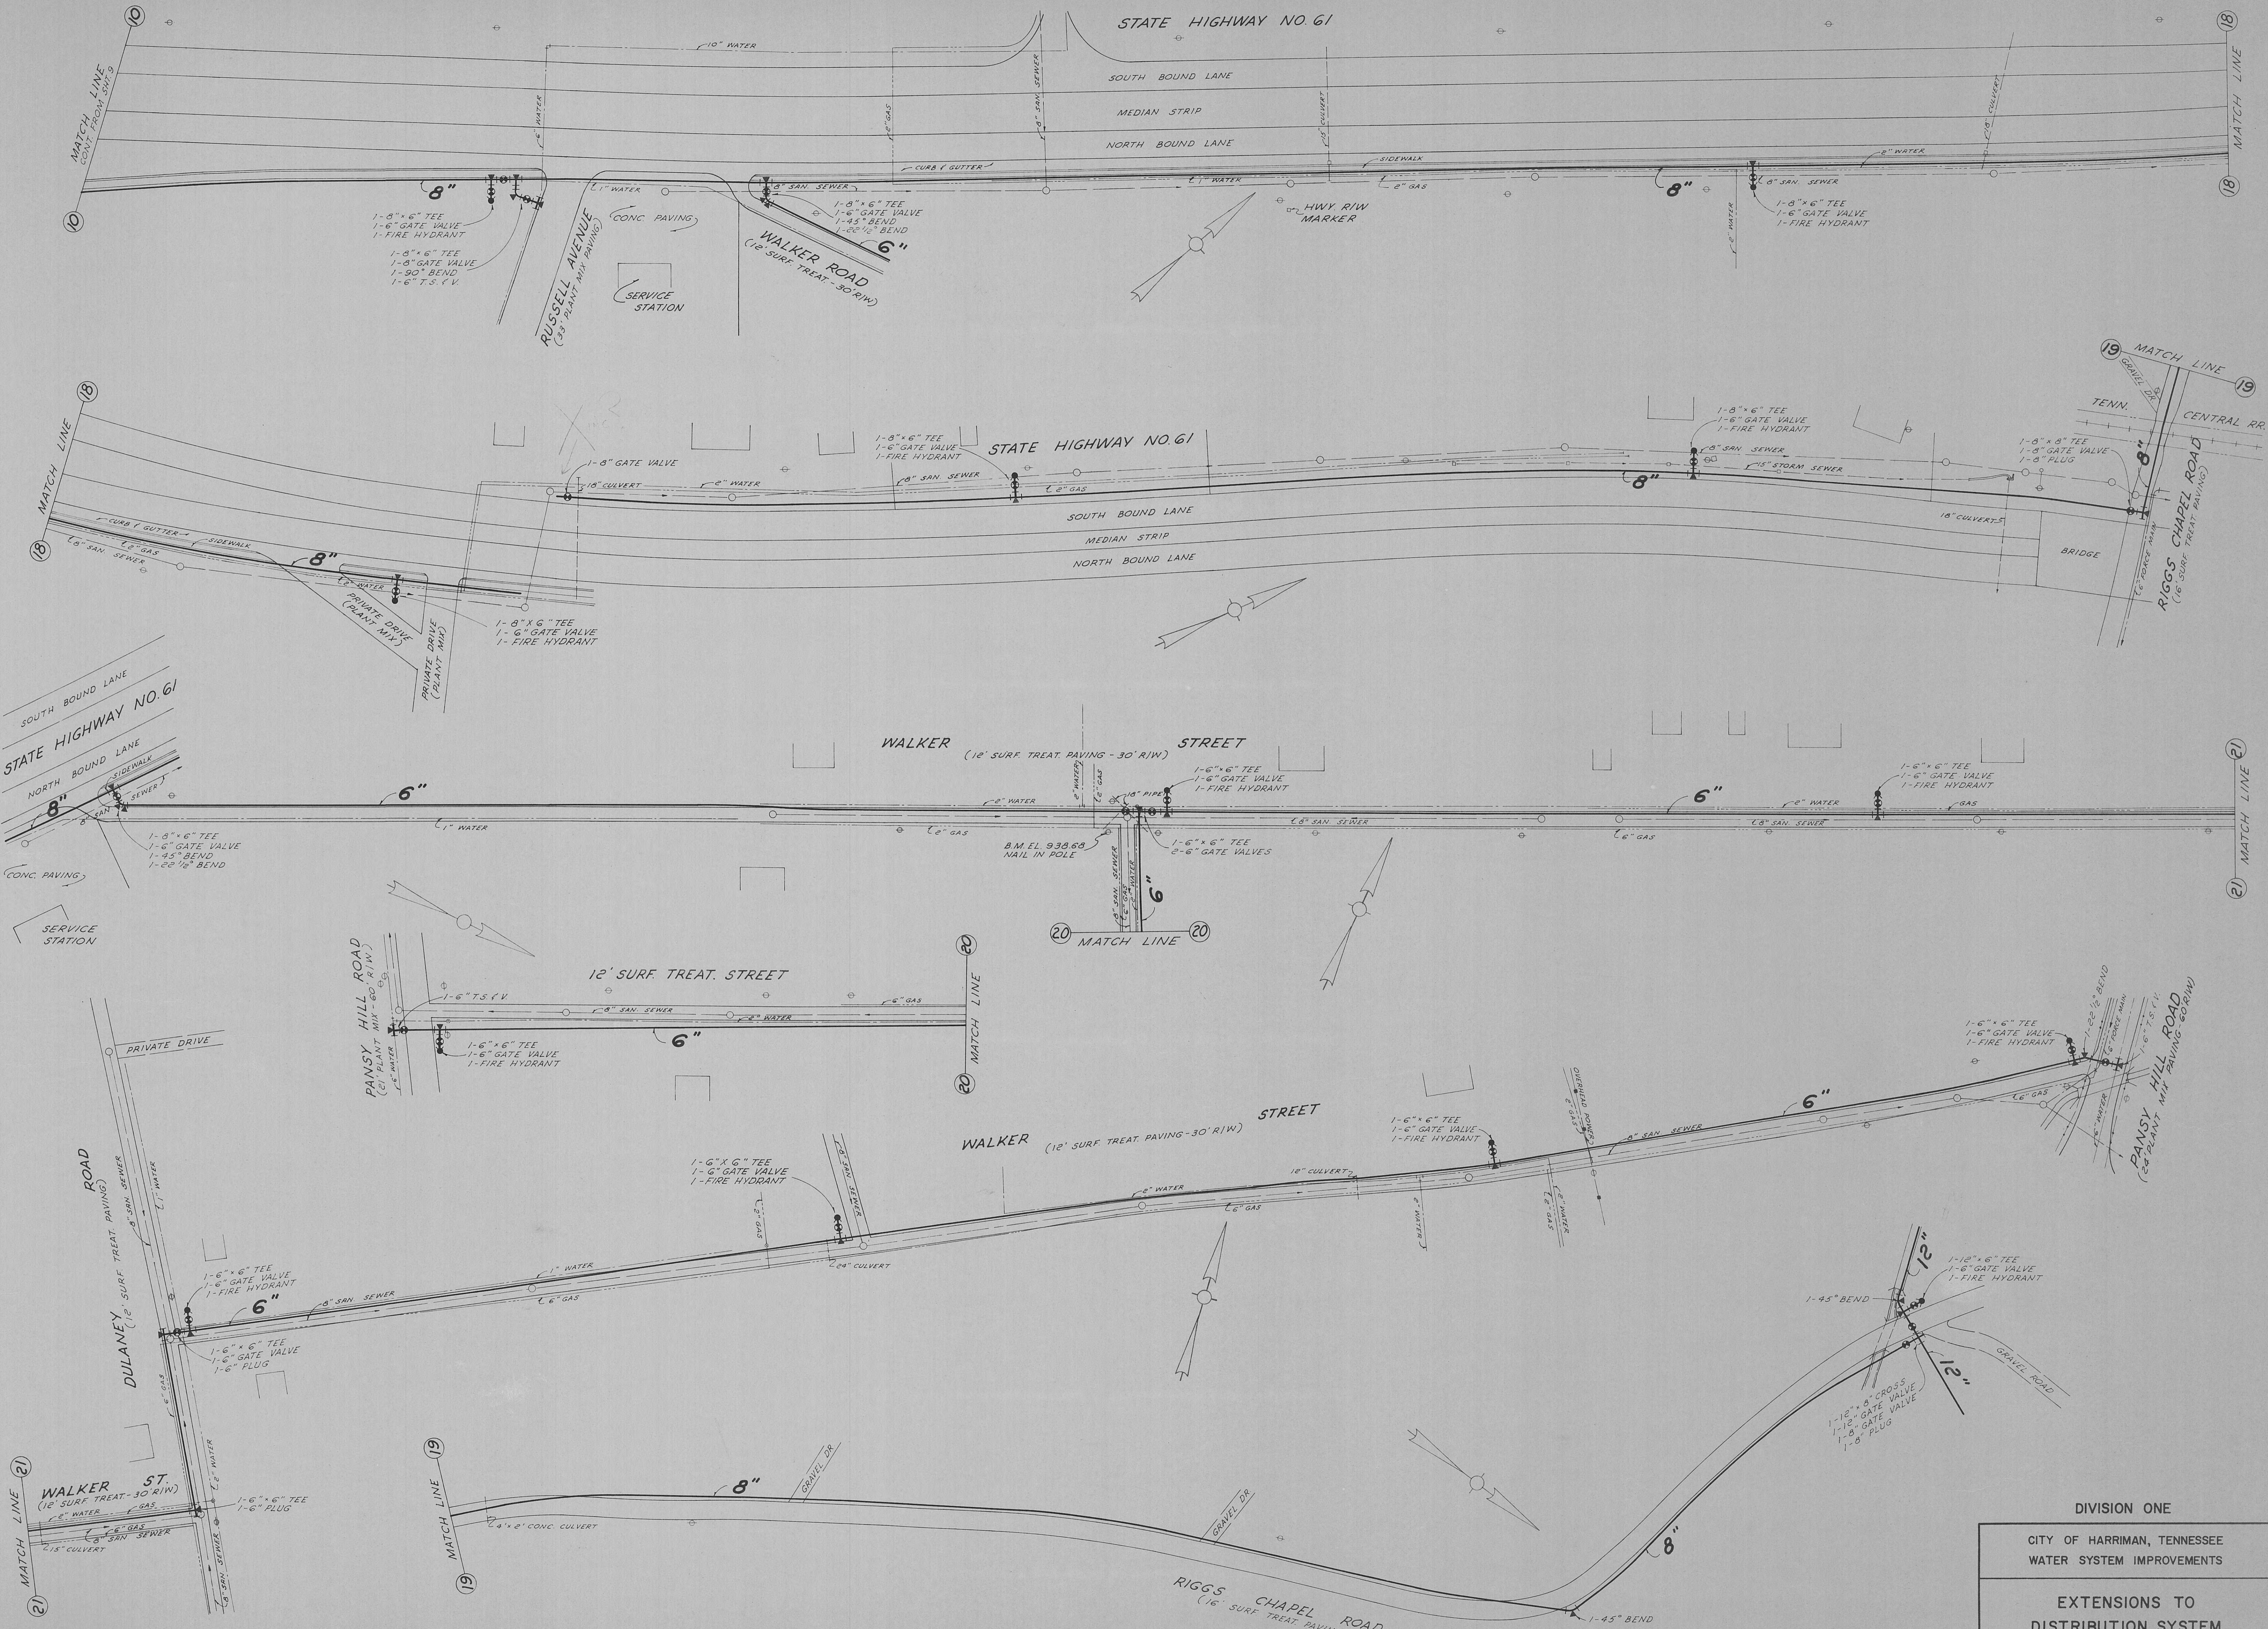



DIVISION ONE
CITY OF HARRIMAN, TENNESSEE
WATER SYSTEM IMPROVEMENTS

  EXTENSIONS TO
DISTRIBUTION SYSTEM





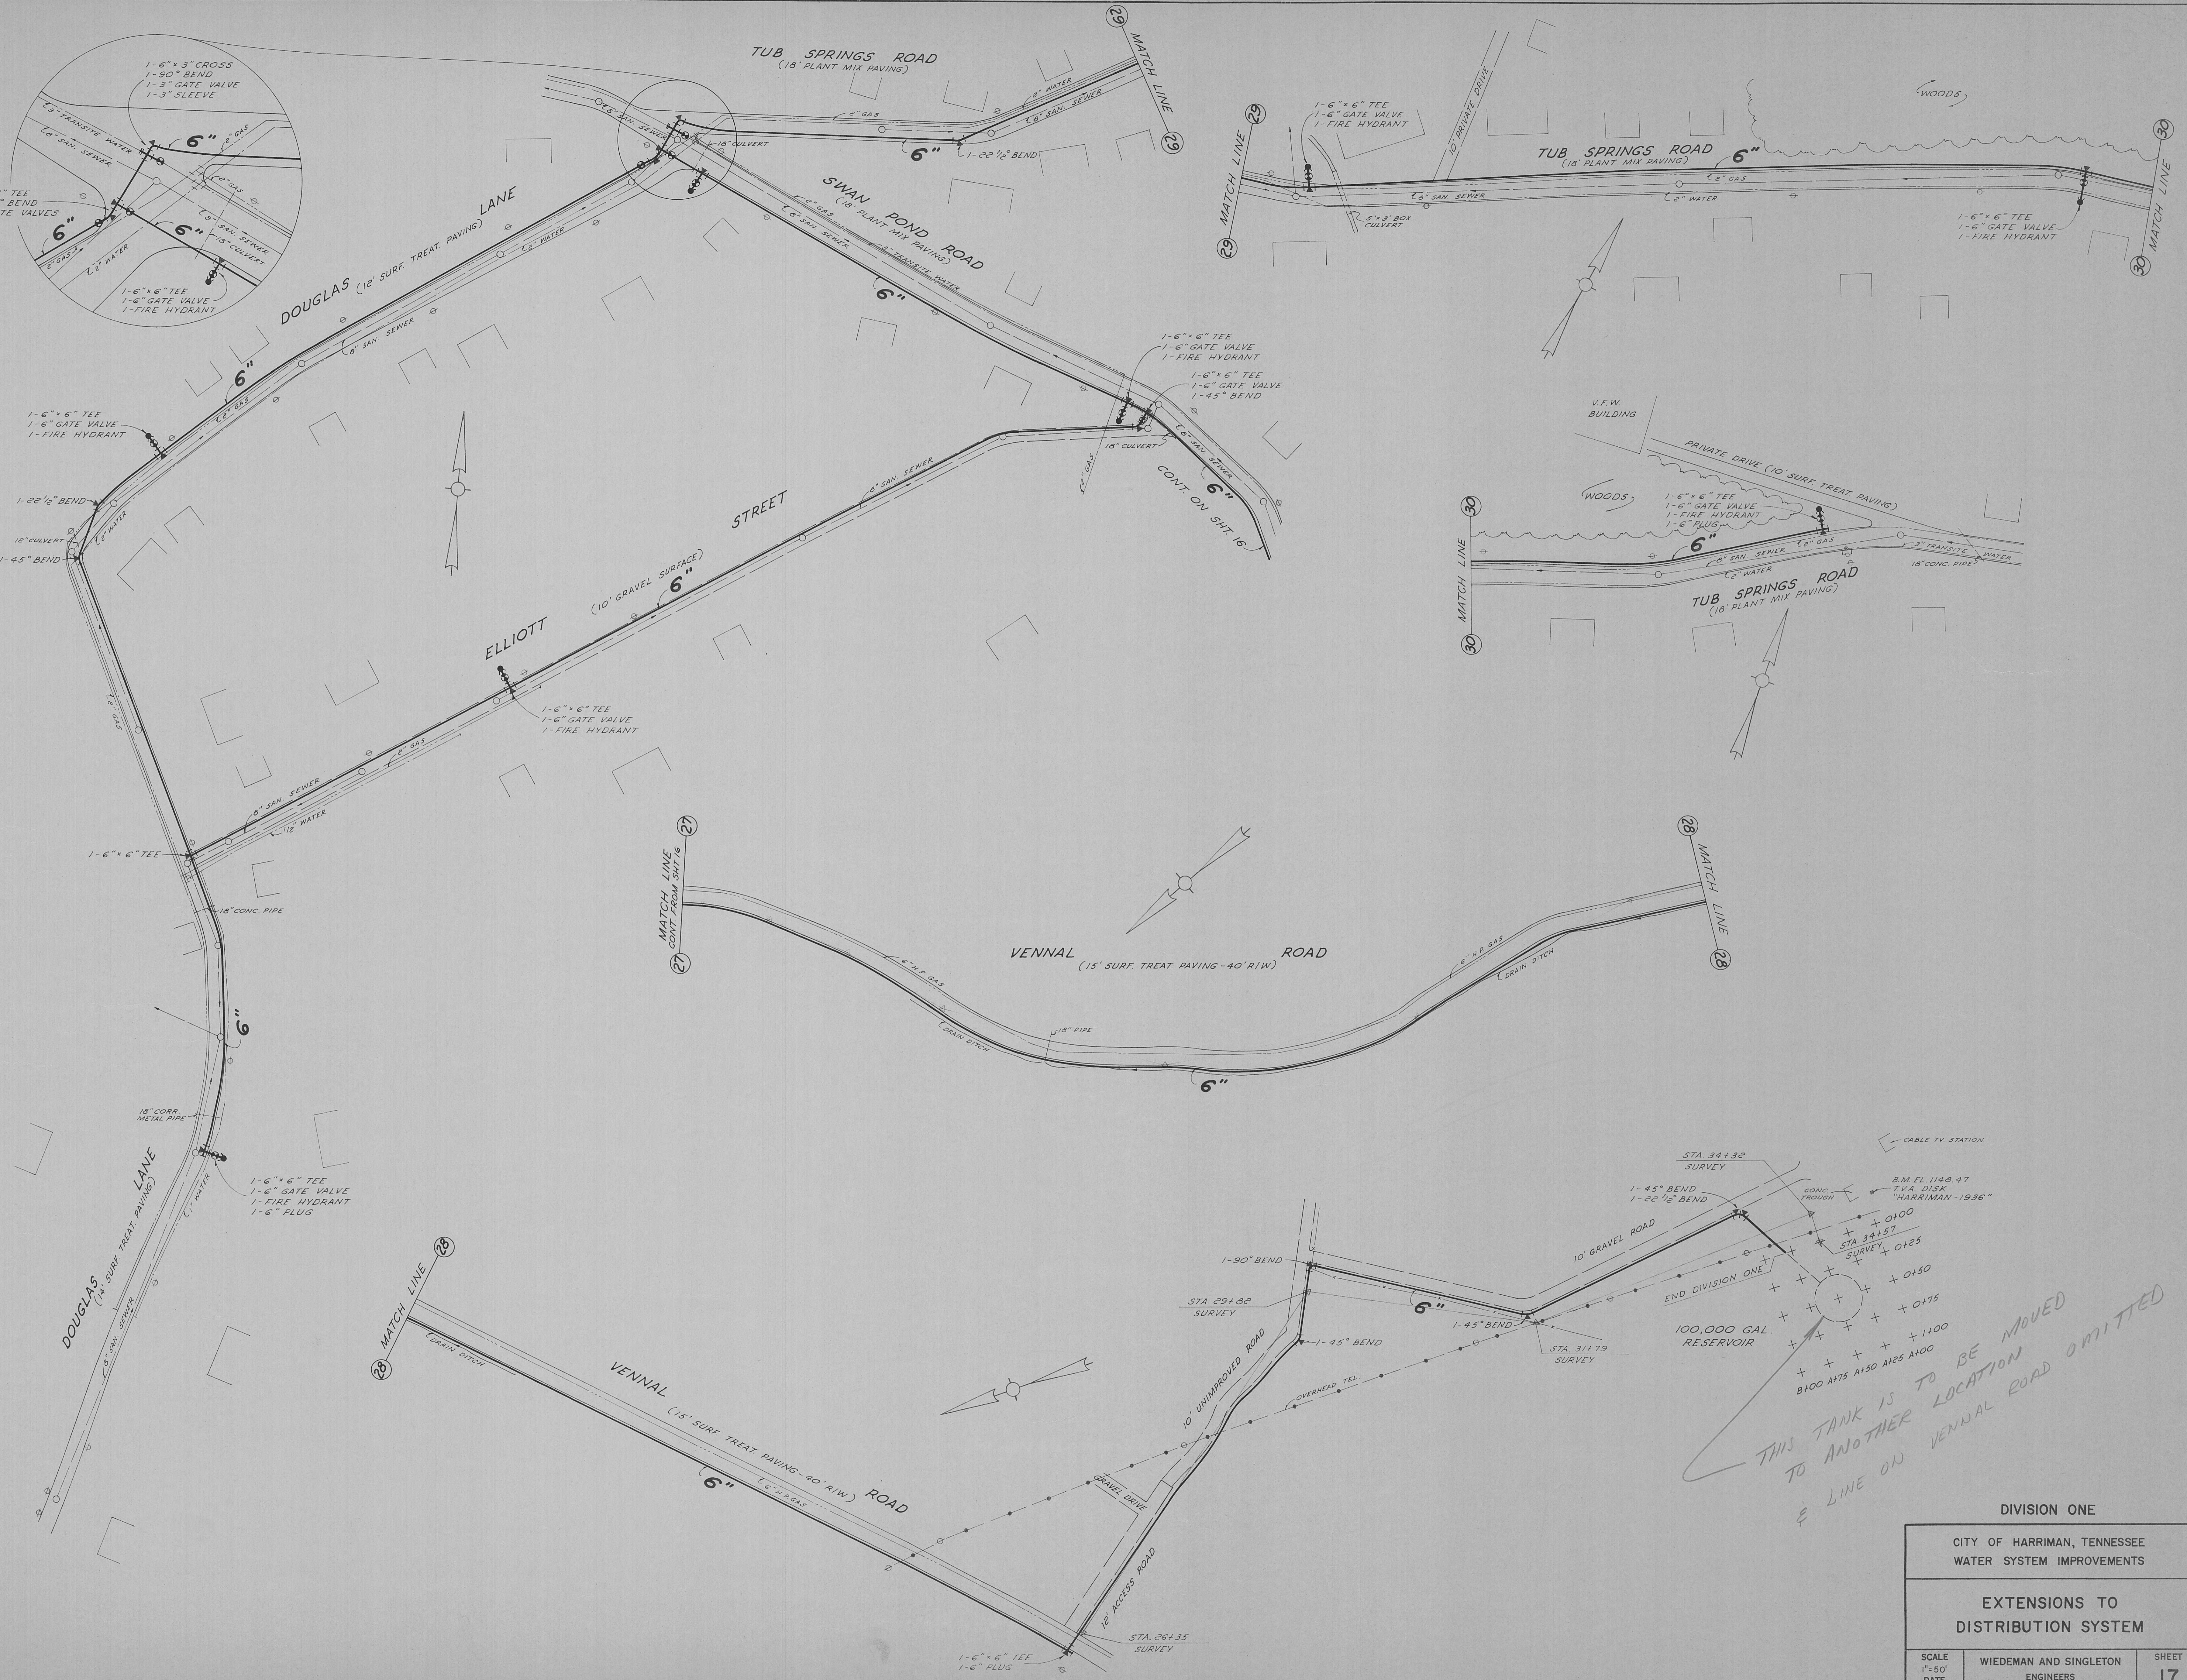

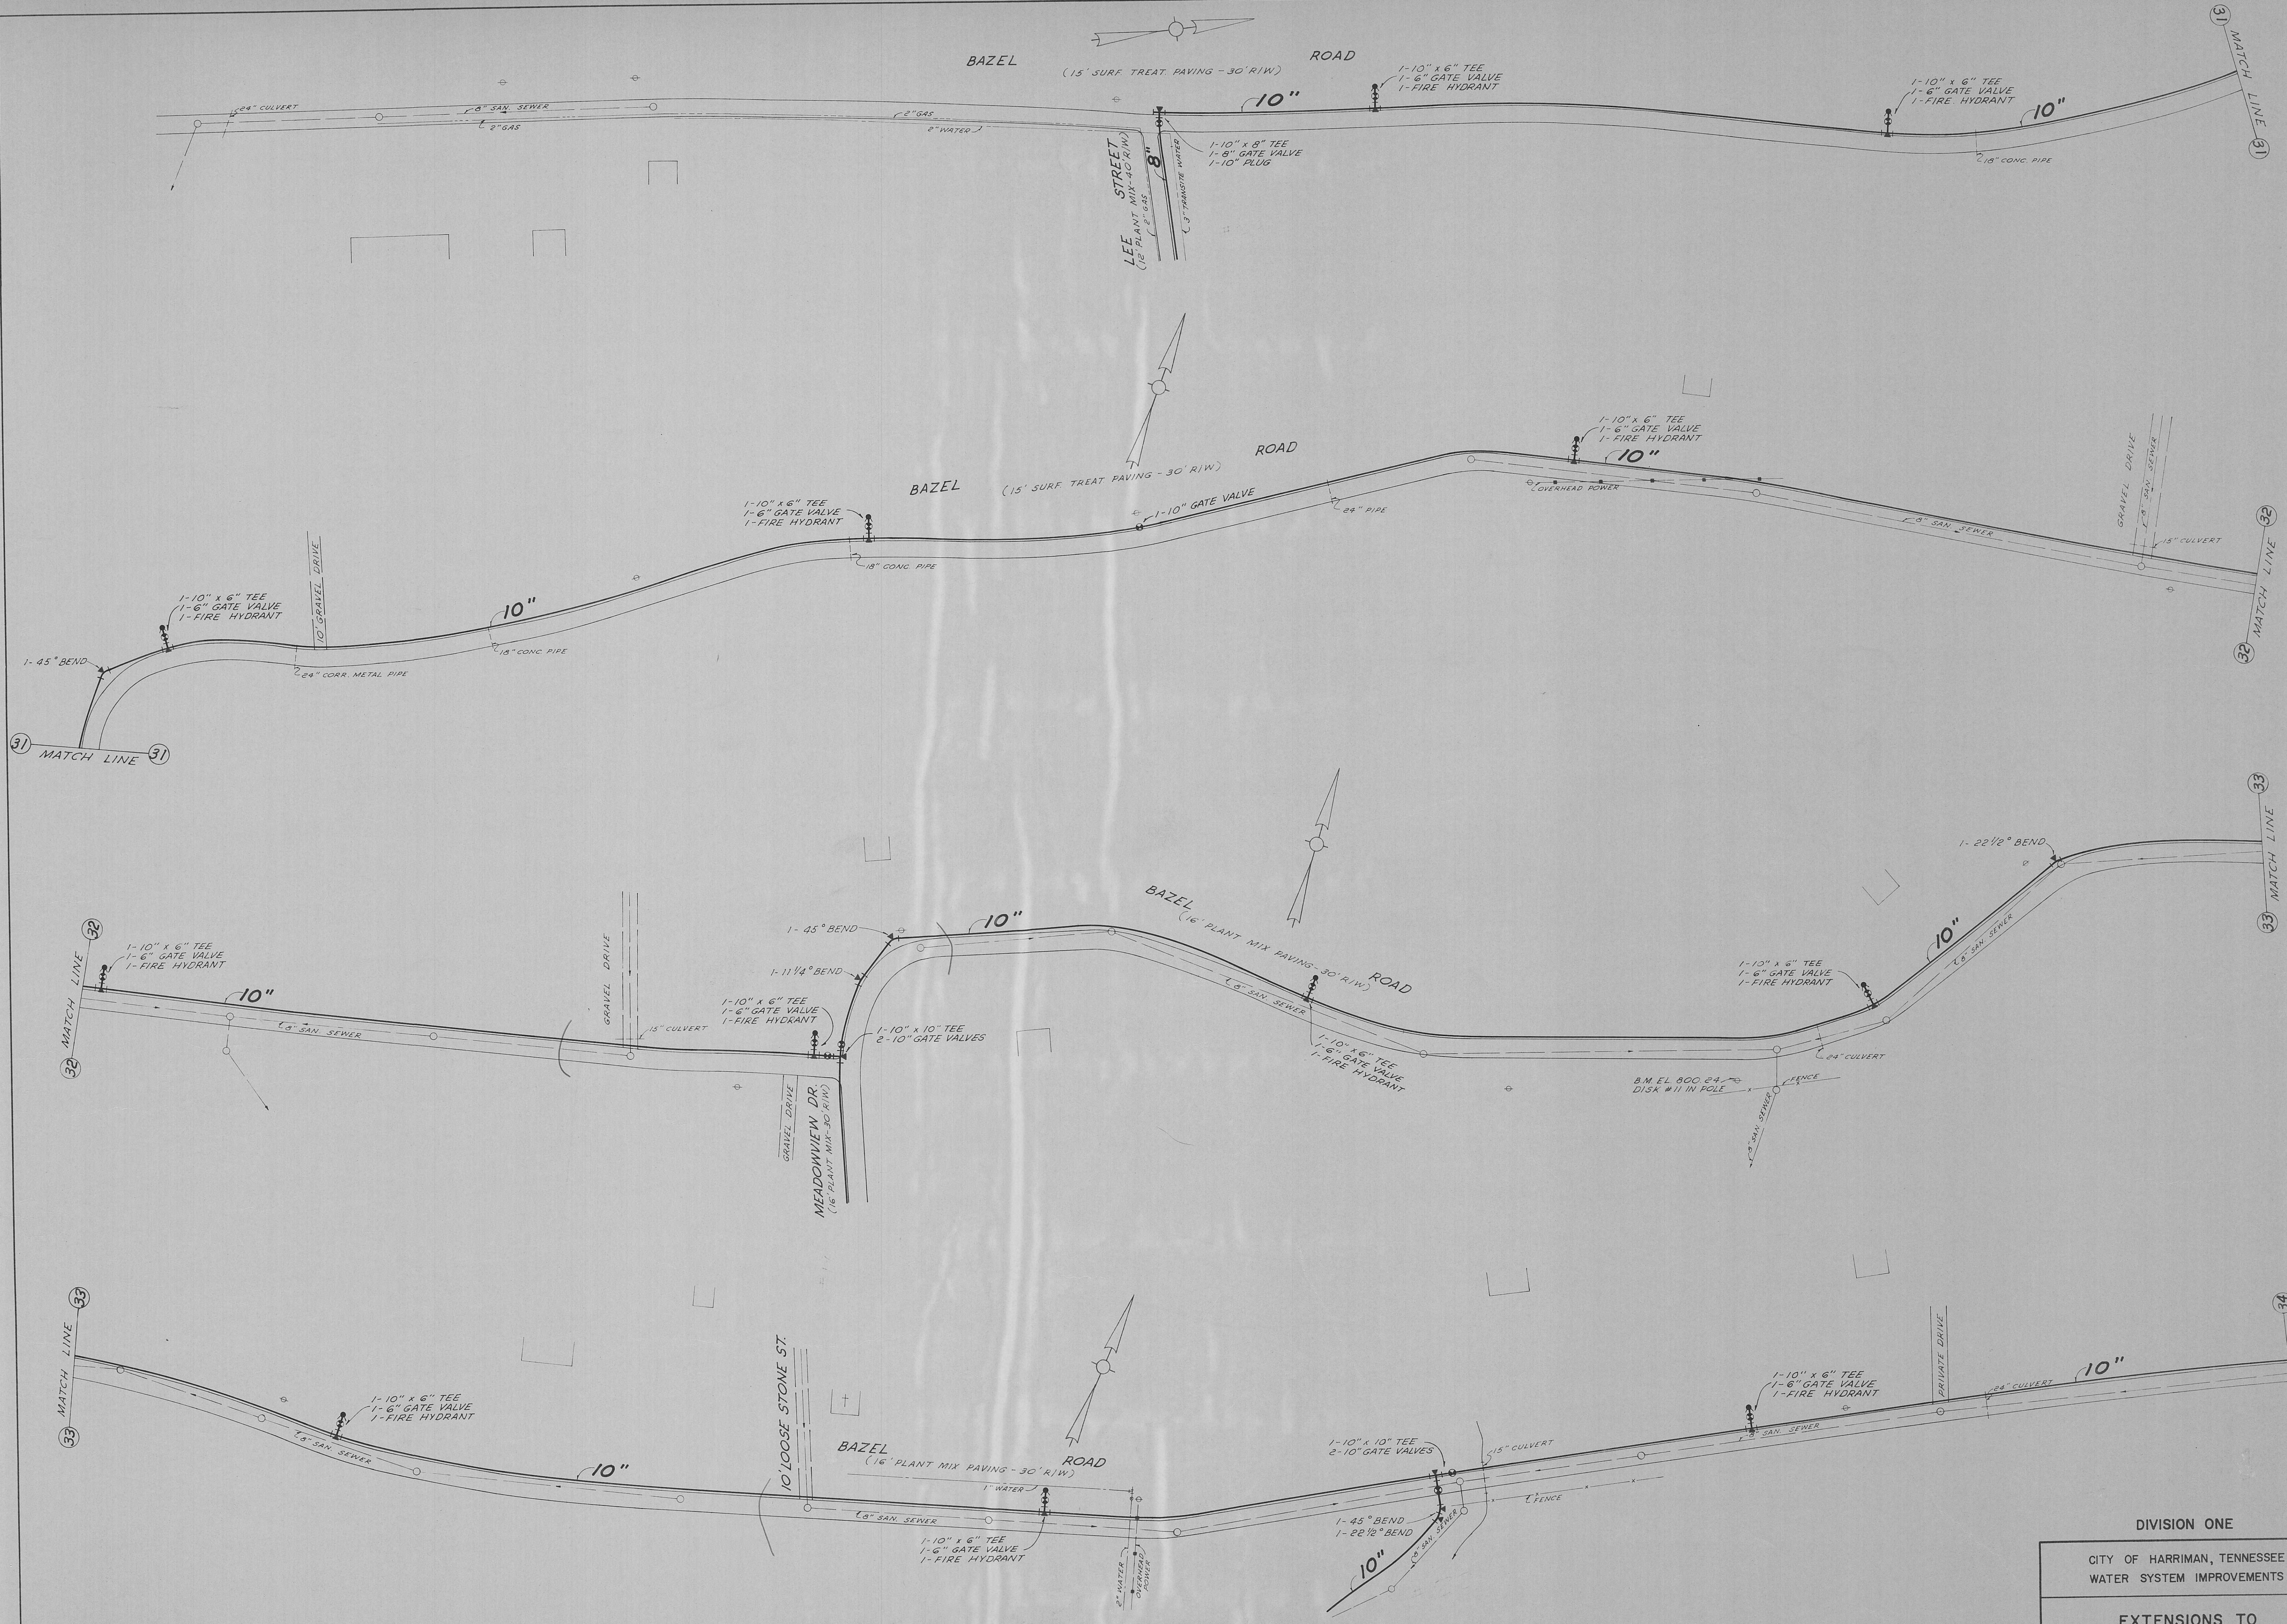

DIVISION ONE

CITY OF HARRIMAN, TENNESSEE
WATER SYSTEM IMPROVEMENTS

EXTENSIONS TO
DISTRIBUTION SYSTEM

SCALE
1" = 50'
DATE
MAY, 1966
WIEDEMAN AND SINGLETON
ENGINEERS
ATLANTA GEORGIA

18





DIVISION ONE
CITY OF HARRIMAN, TENNESSEE
WATER SYSTEM IMPROVEMENT

LOCATION MAP

SCALE
1" = 800'
DATE
MAY, 1966
ENGINEERS
ATLANTA
GEORGIA

Div. Two - Tank Foundations & Bunker Stations
Div. Three - Tanks
X 5 Sheets

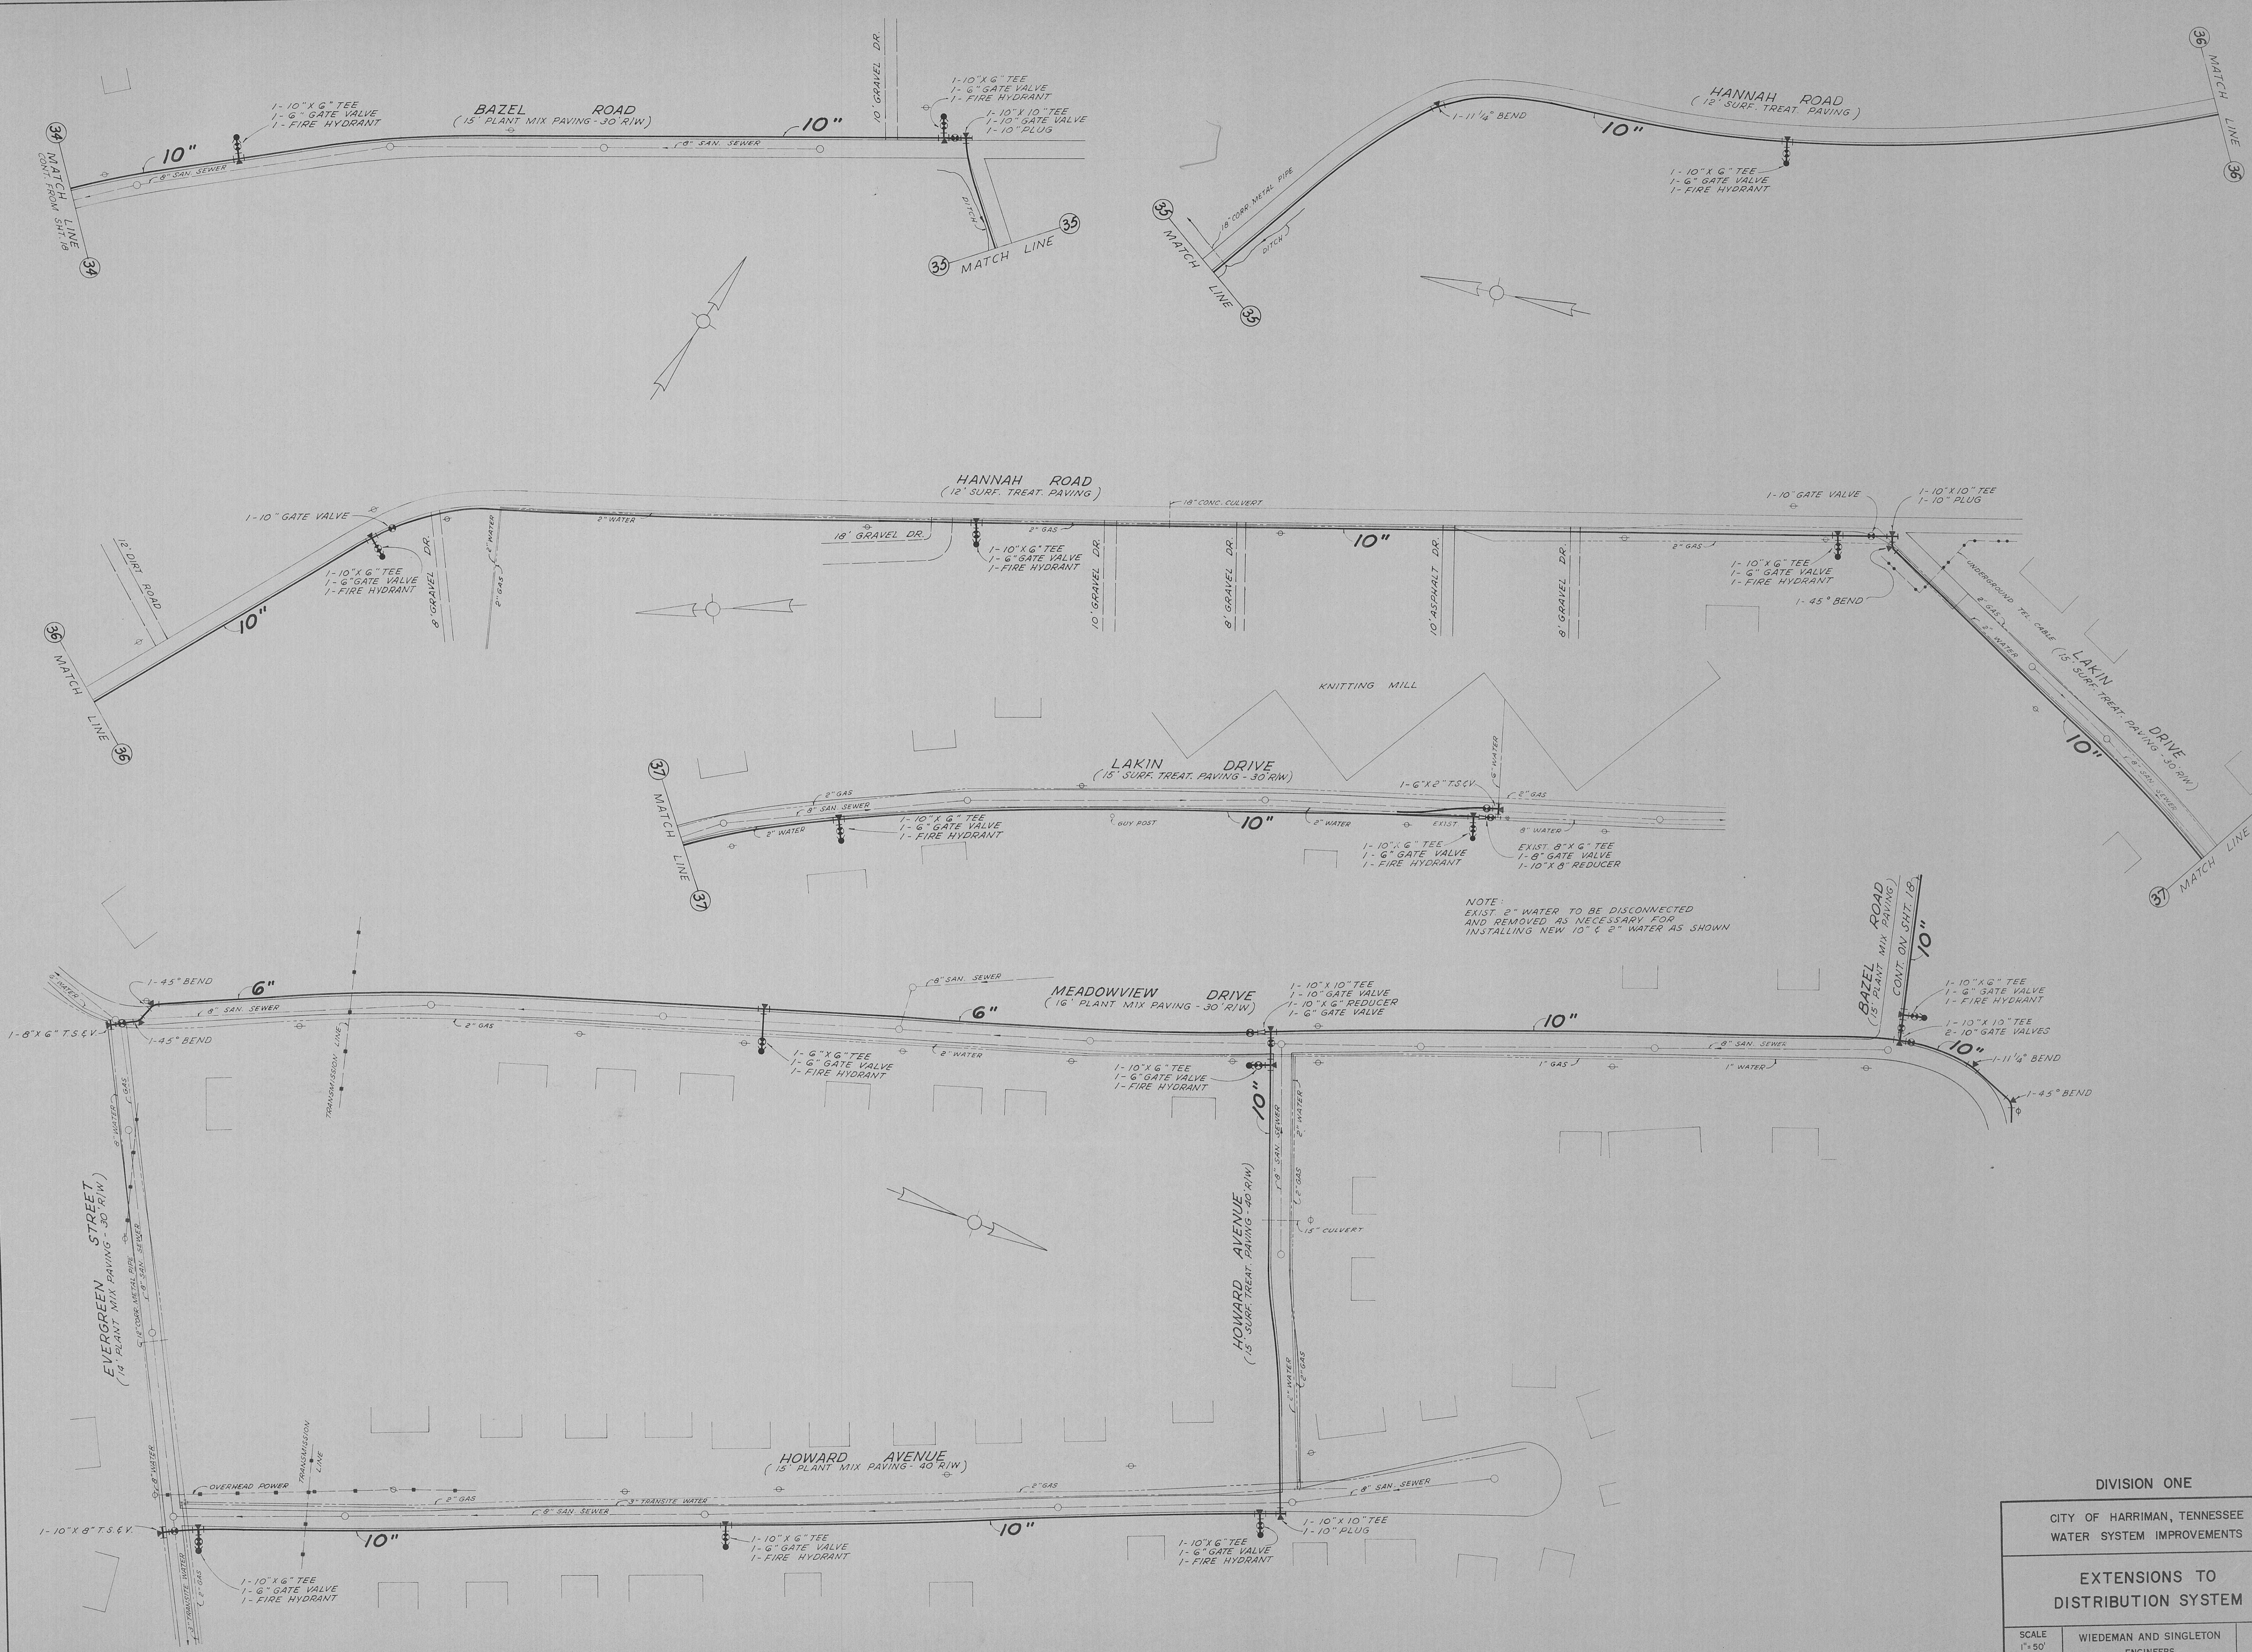

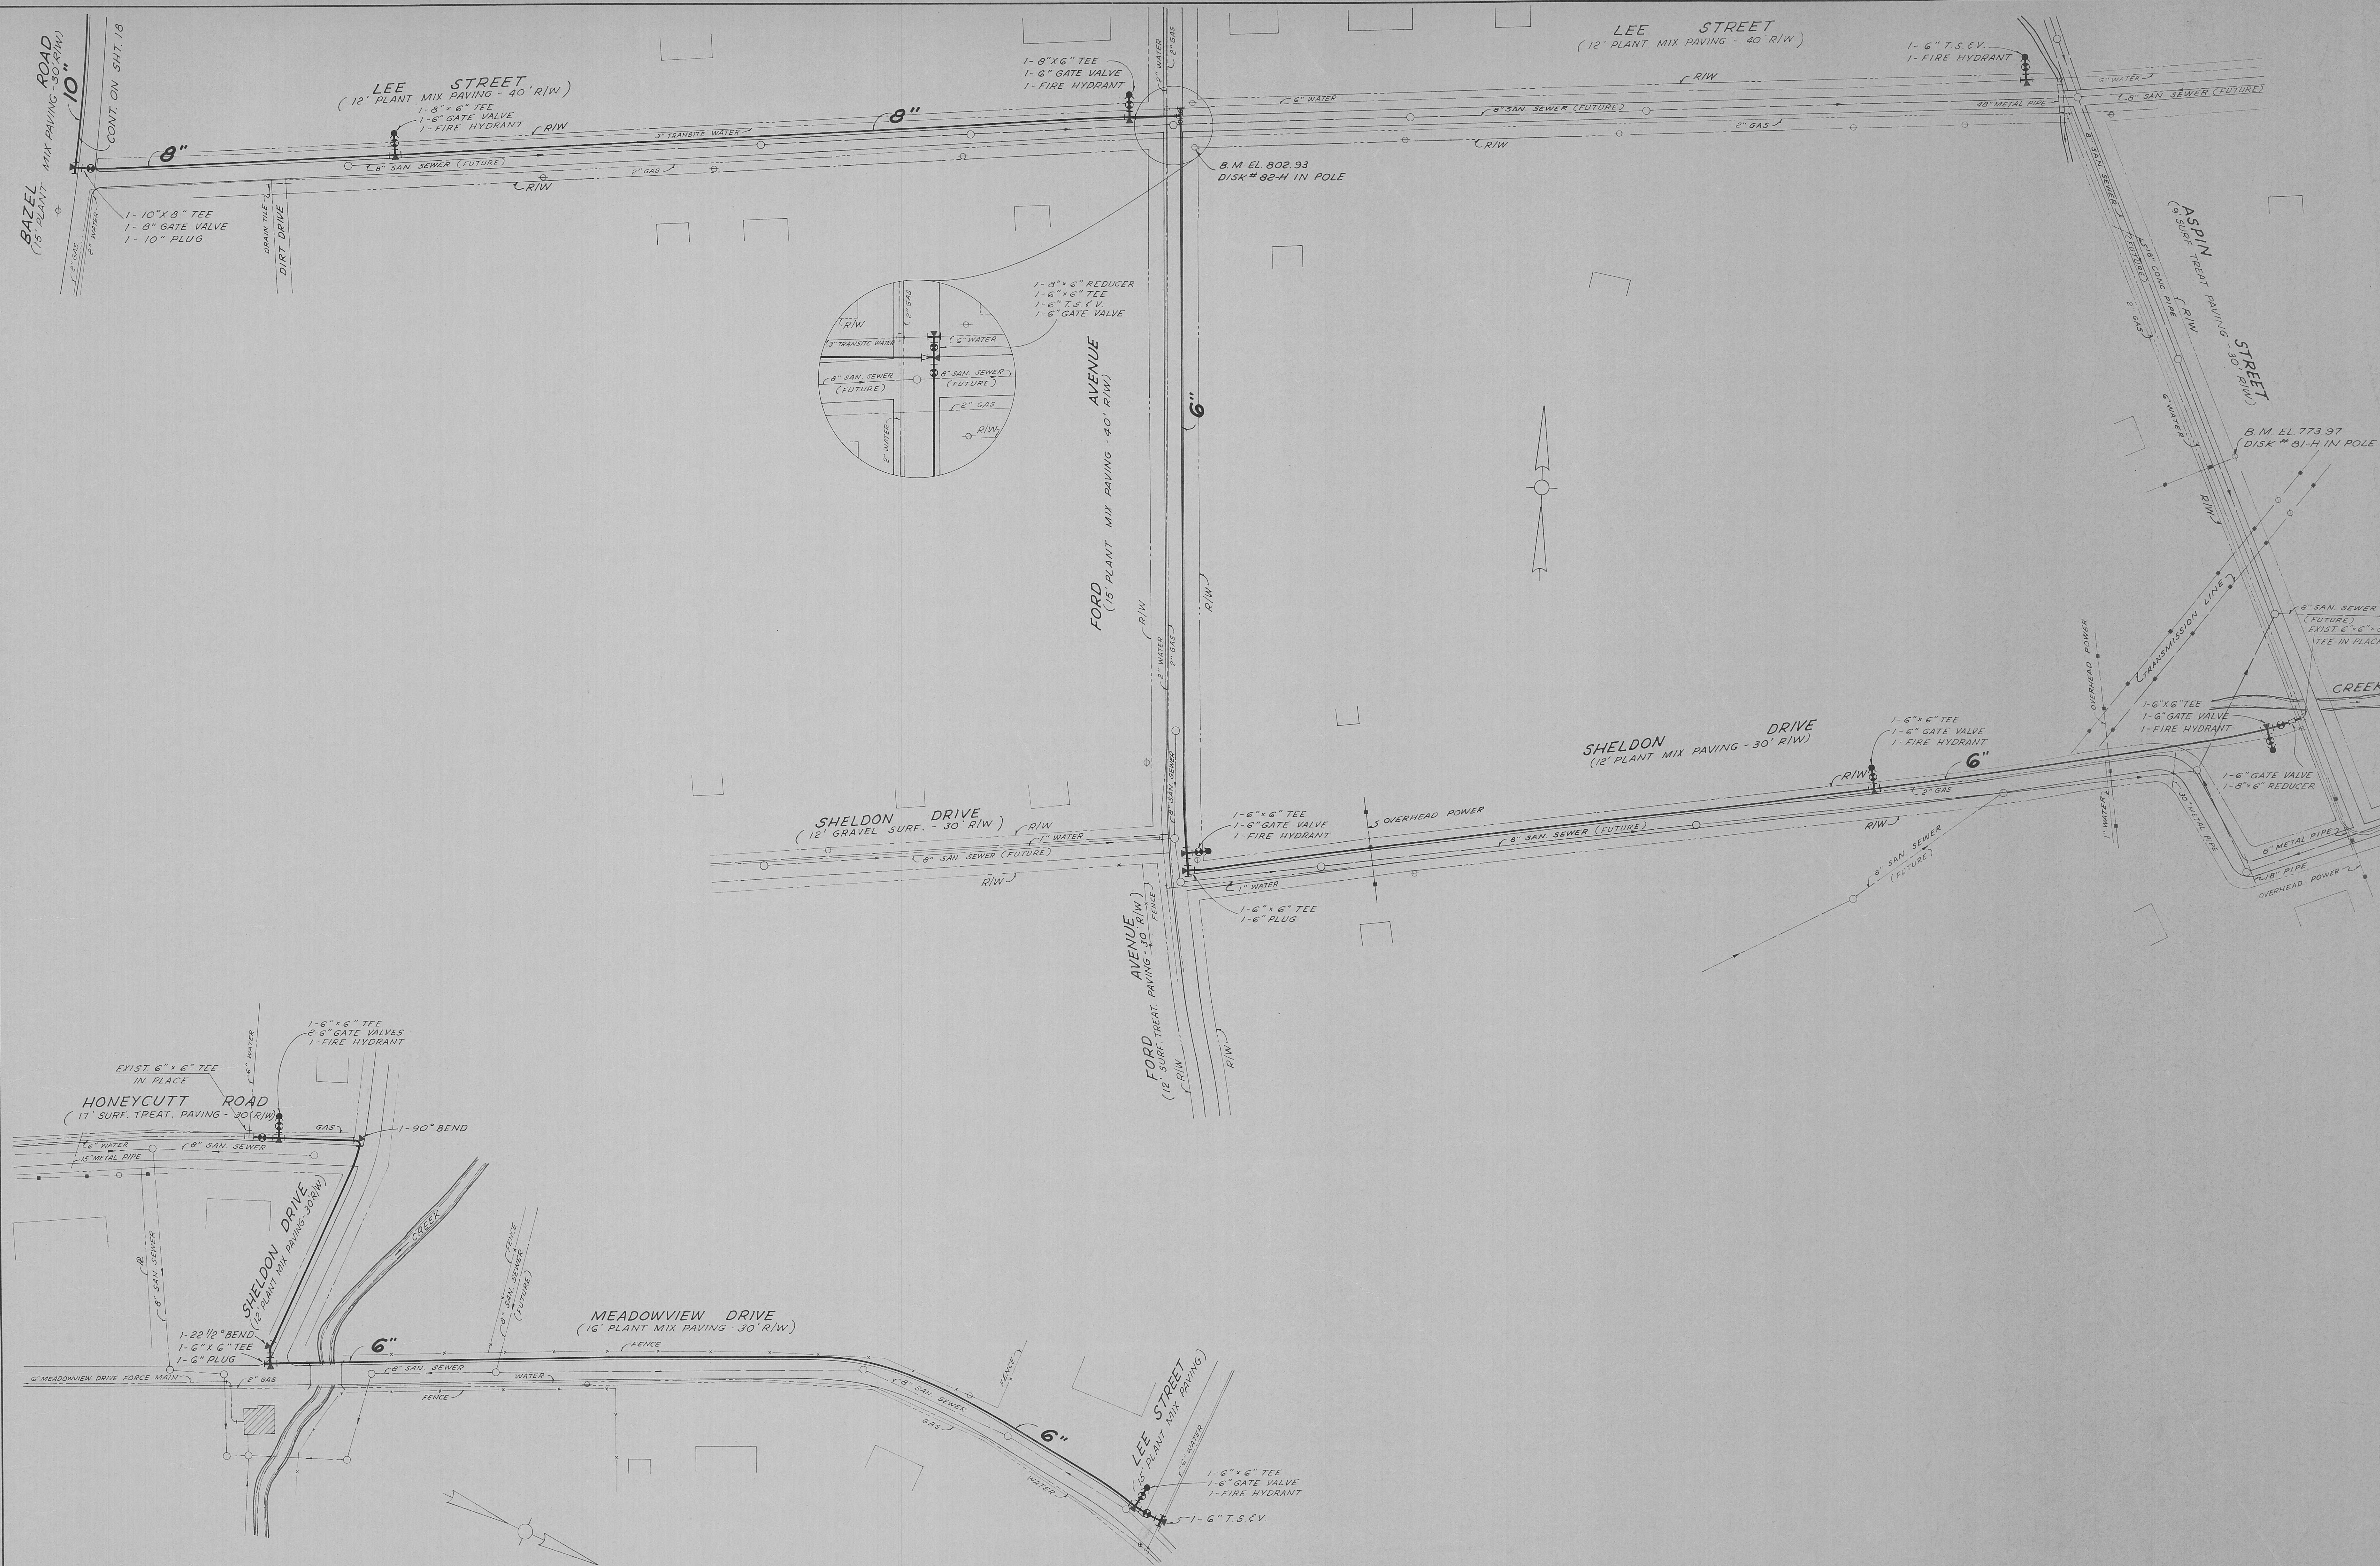


DIVISION ONE

CITY OF HARRIMAN, TENNESSEE
WATER SYSTEM IMPROVEMENTS

EXTENSIONS TO
DISTRIBUTION SYSTEM

SCALE
1"-50'
DATE
MAY, 1966
WIEDEMAN AND SINGLETON
ENGINEERS
ATLANTA, GEORGIA

OF
20

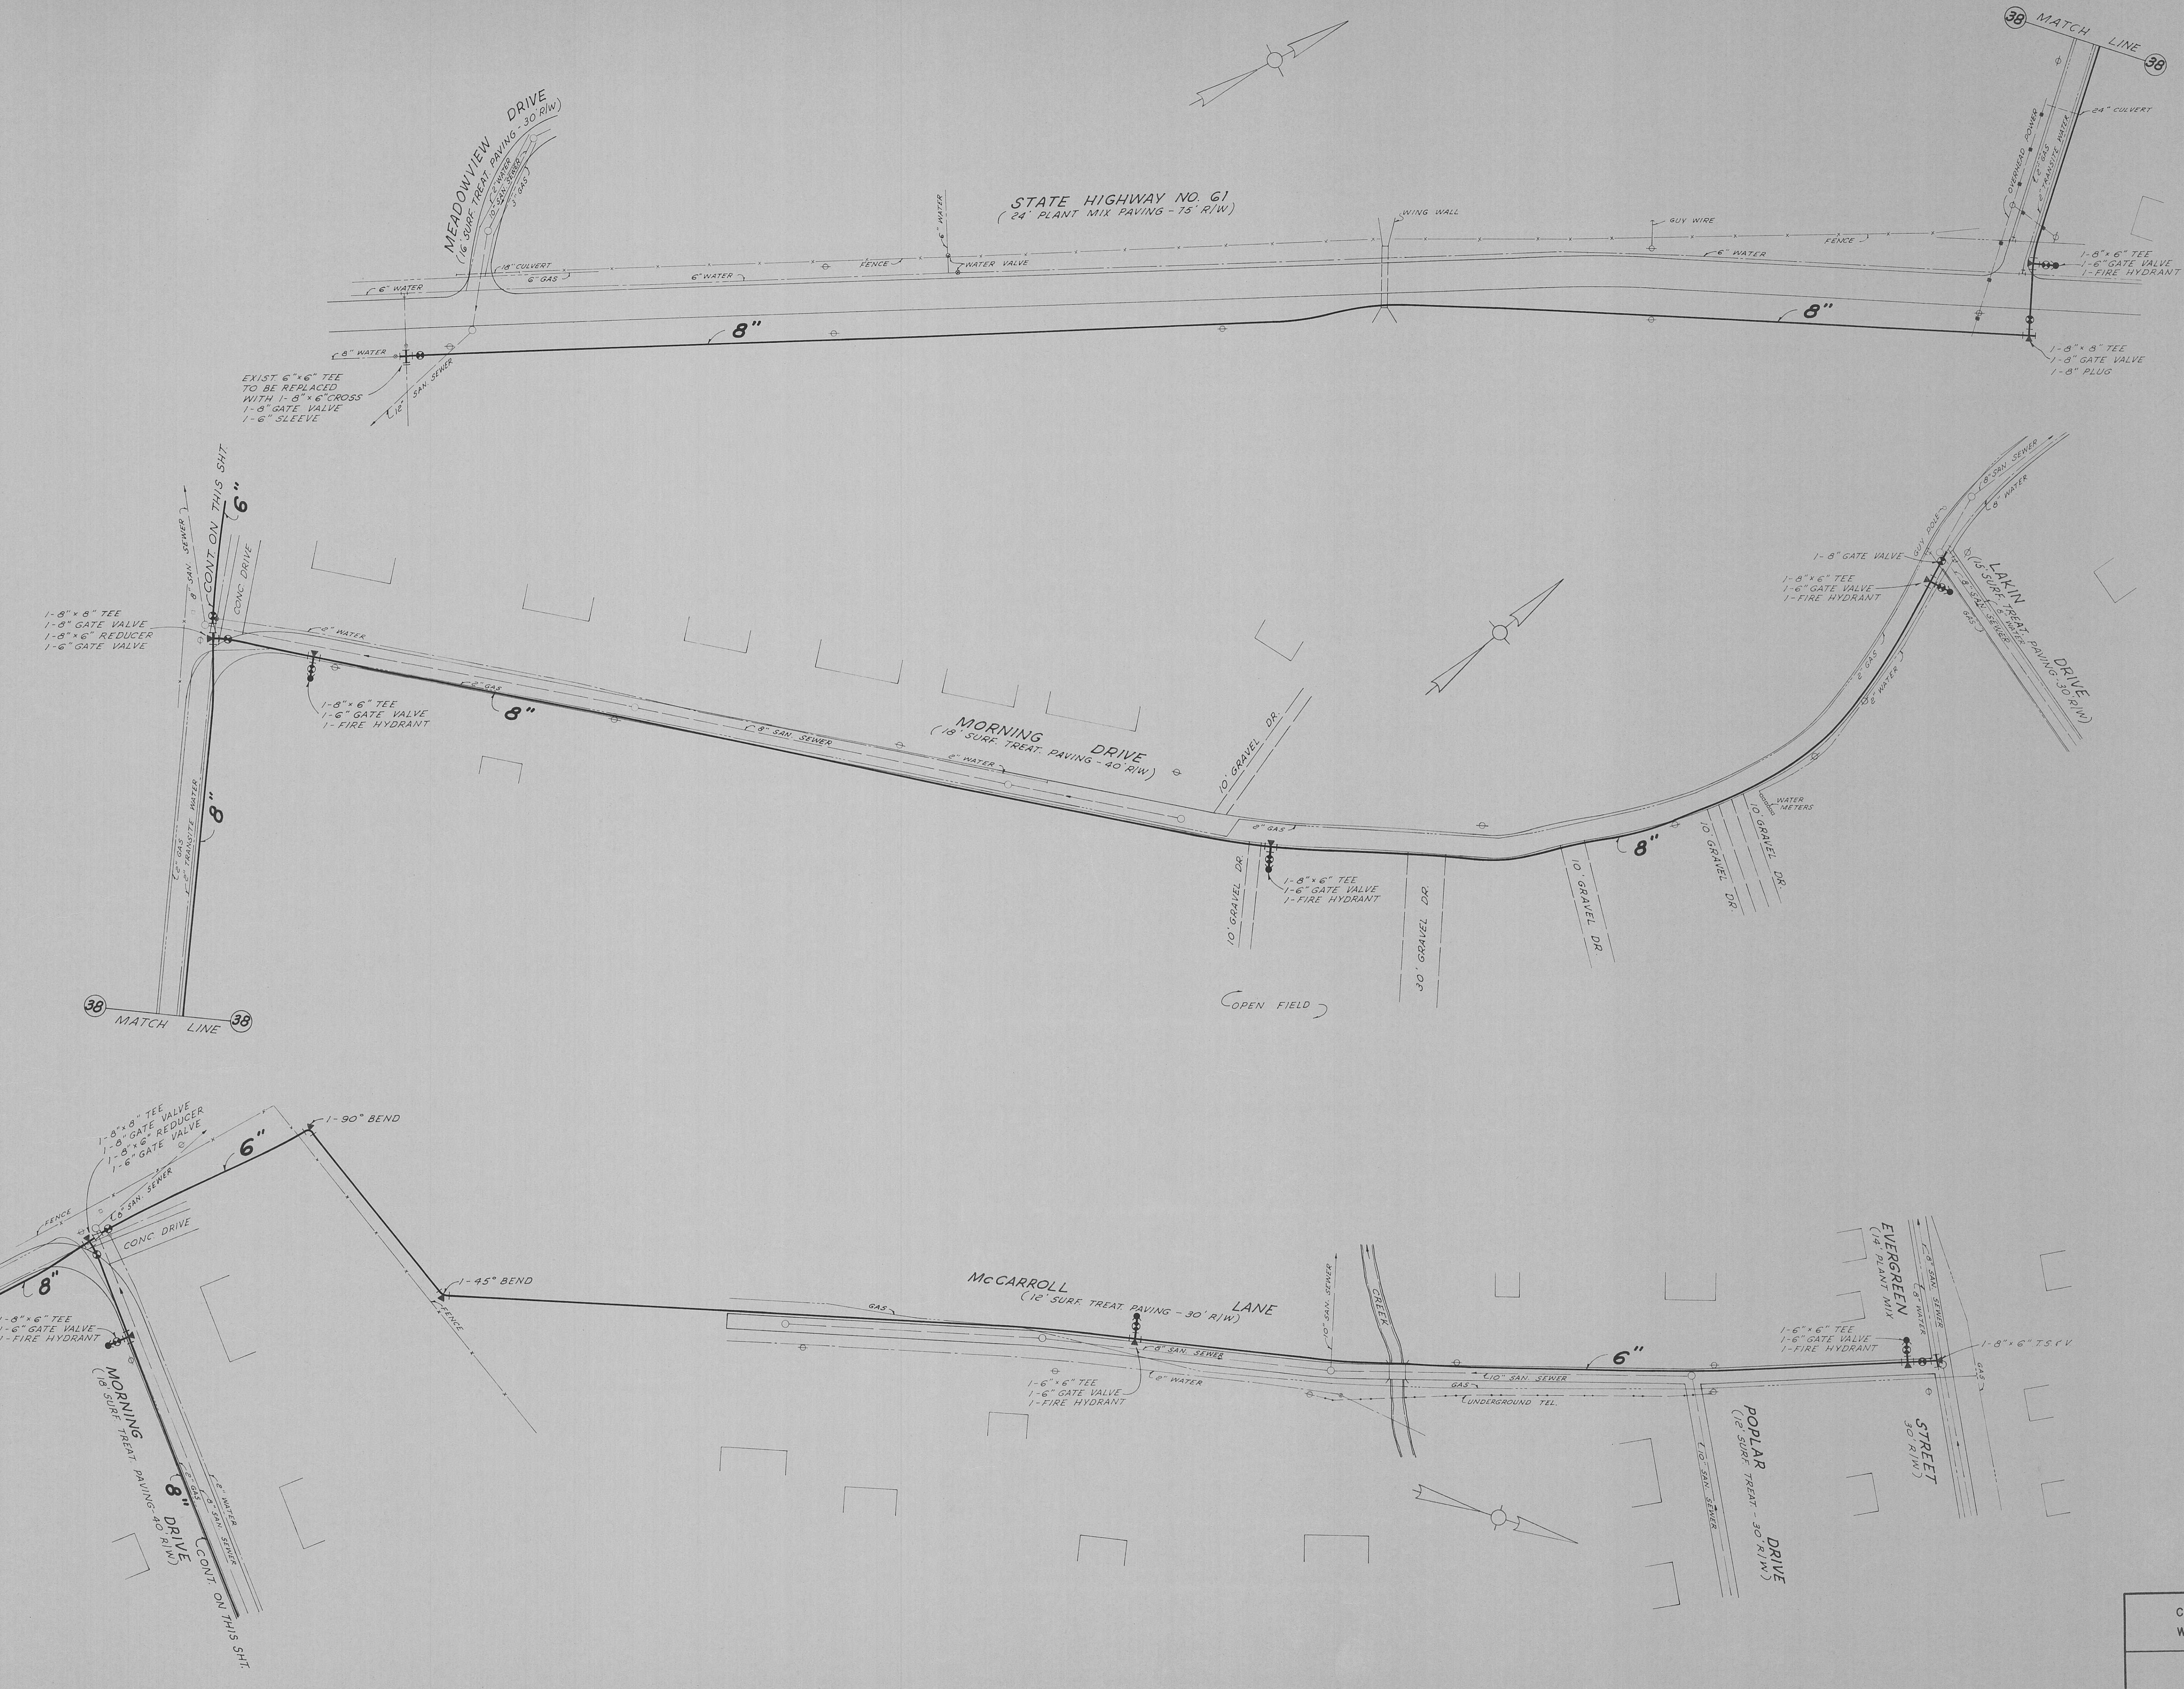

DIVISION ONE

CITY OF HARRIMAN, TENNESSEE
WATER SYSTEM IMPROVEMENTS

EXTENSIONS TO
DISTRIBUTION SYSTEM

SCALE
1"-50'
DATE
MAY, 1966

WIEDEMAN AND SINGLETON
ENGINEERS
ATLANTA GEORGIA


OF
21





CITY OF HARRIMAN, TENNESSEE
WATER SYSTEM IMPROVEMENTS

EXTENSIONS TO
DISTRIBUTION SYSTEM


SCALE 1'-50' HORZ DATE MAY, 1966	WIEDEMAN AND SINGLETON ENGINEERS ATLANTA	GEORGIA
---	--	---------

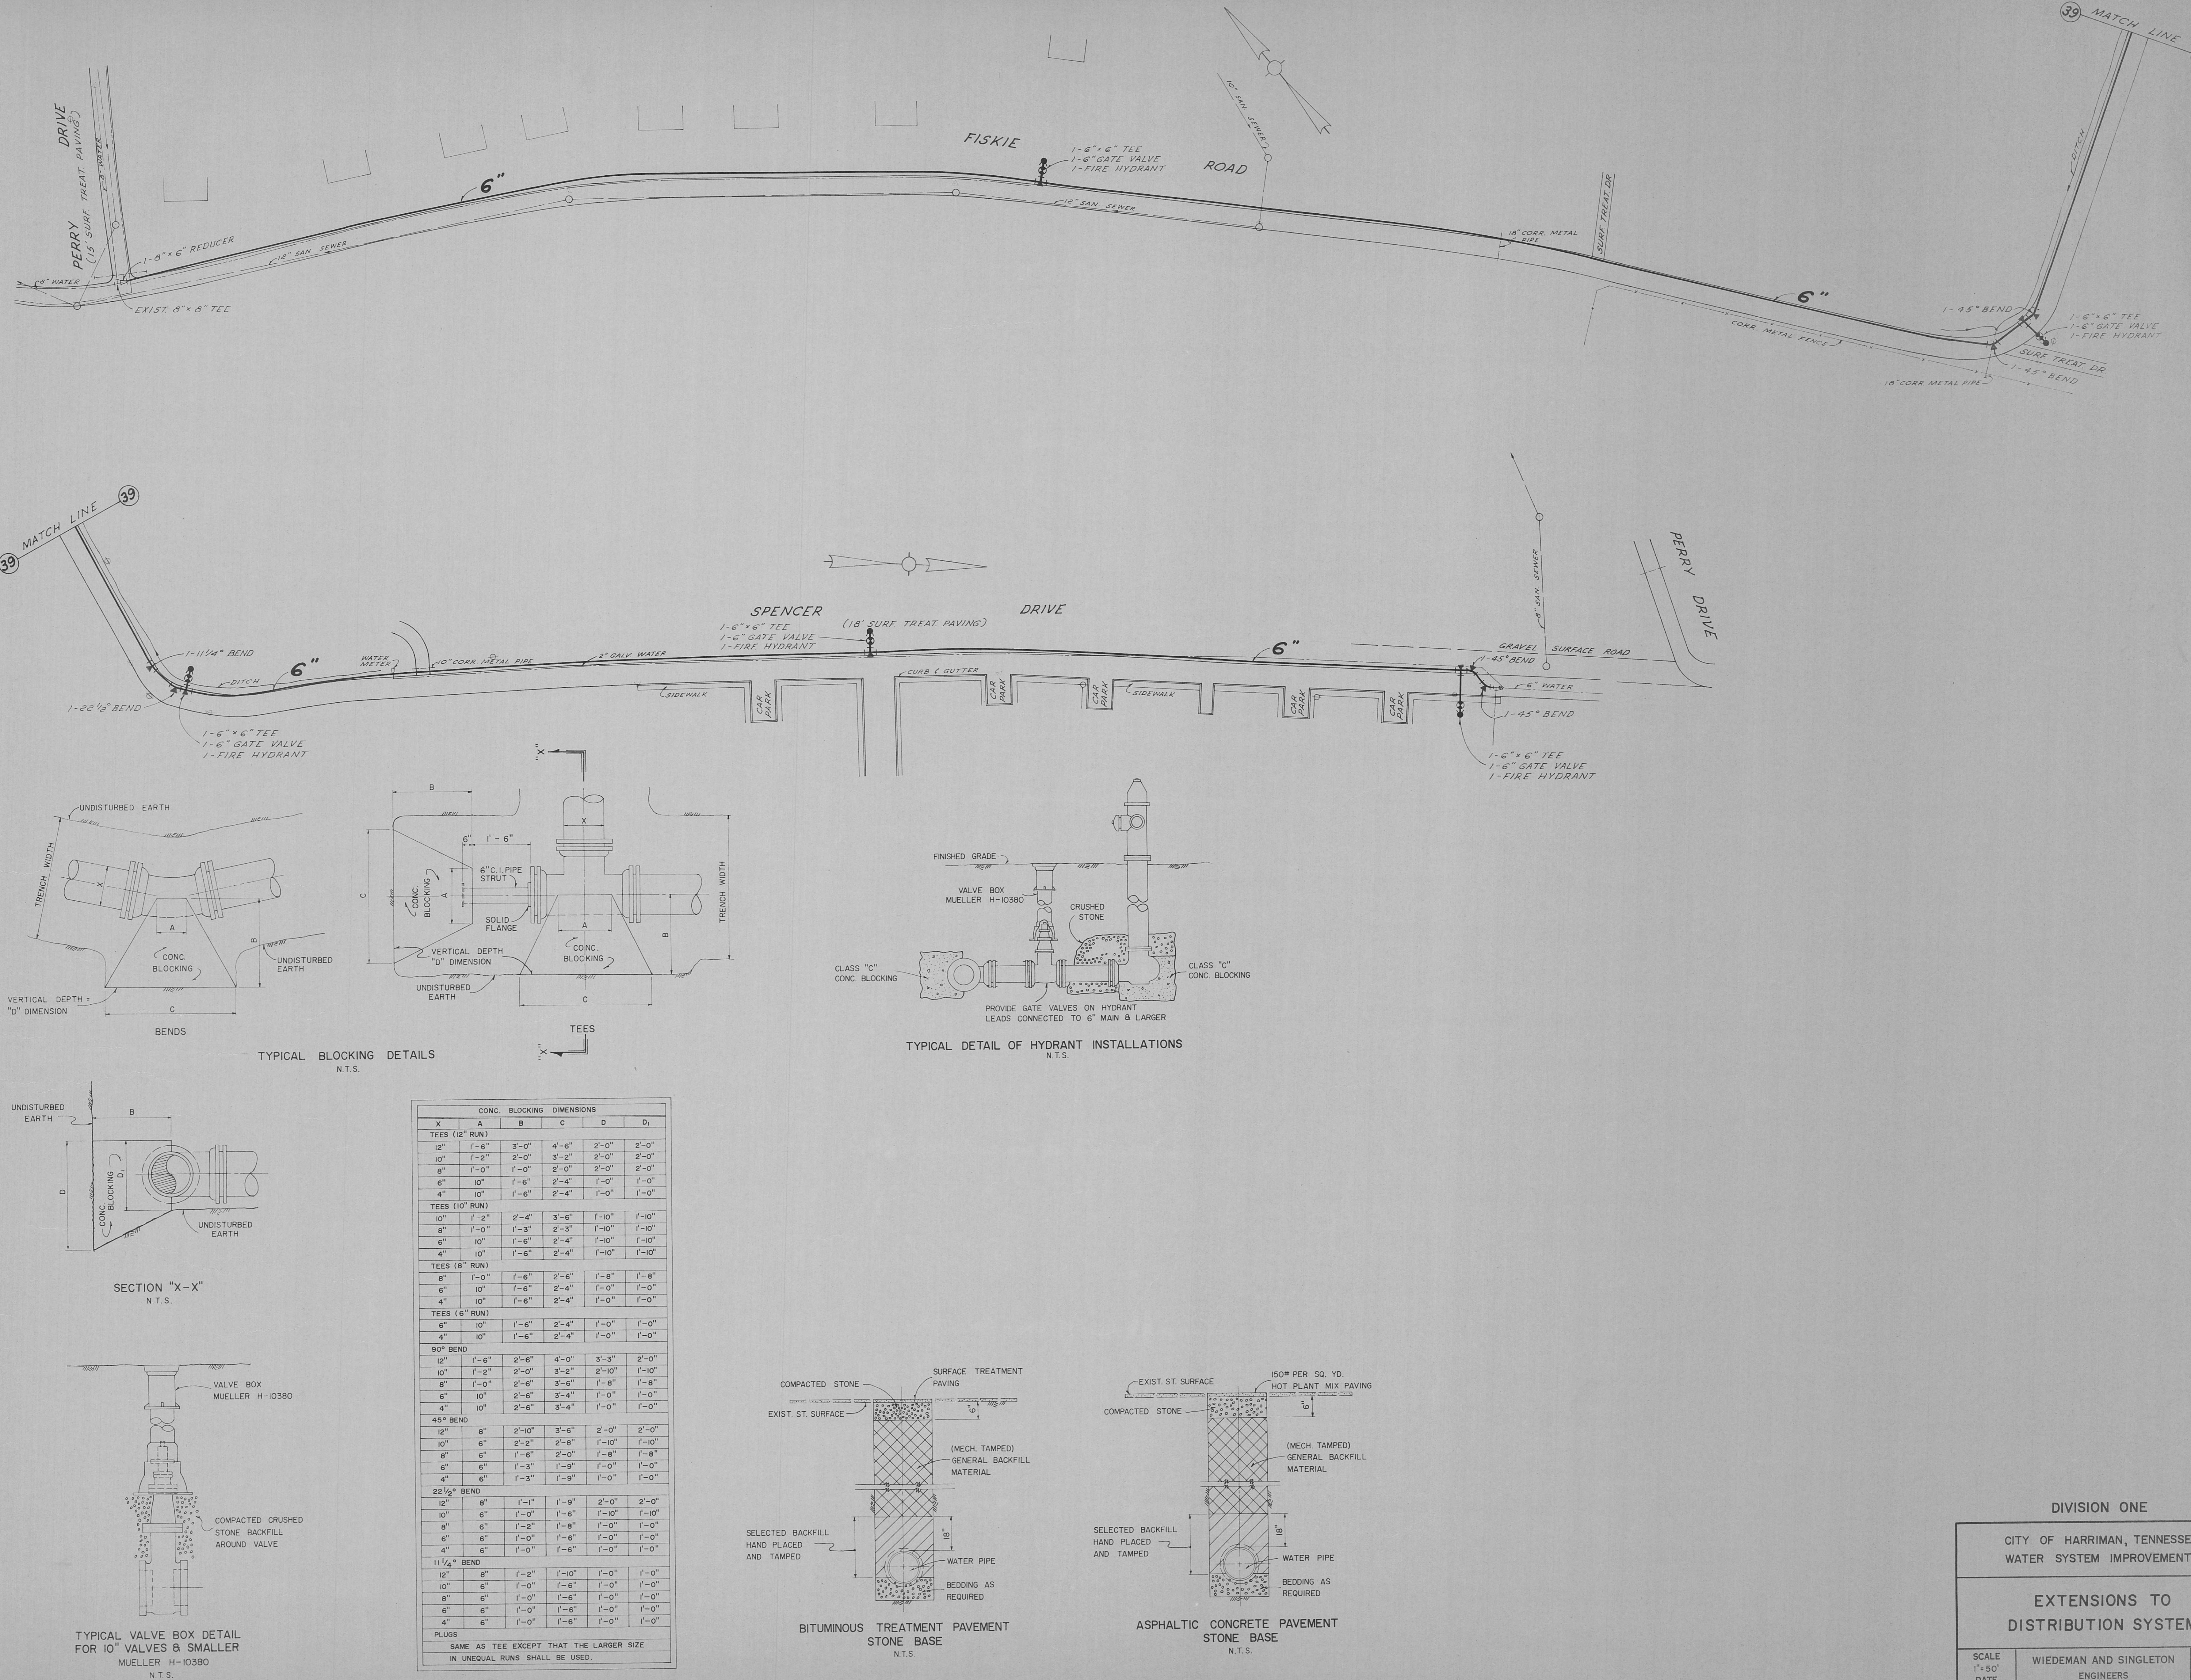

 


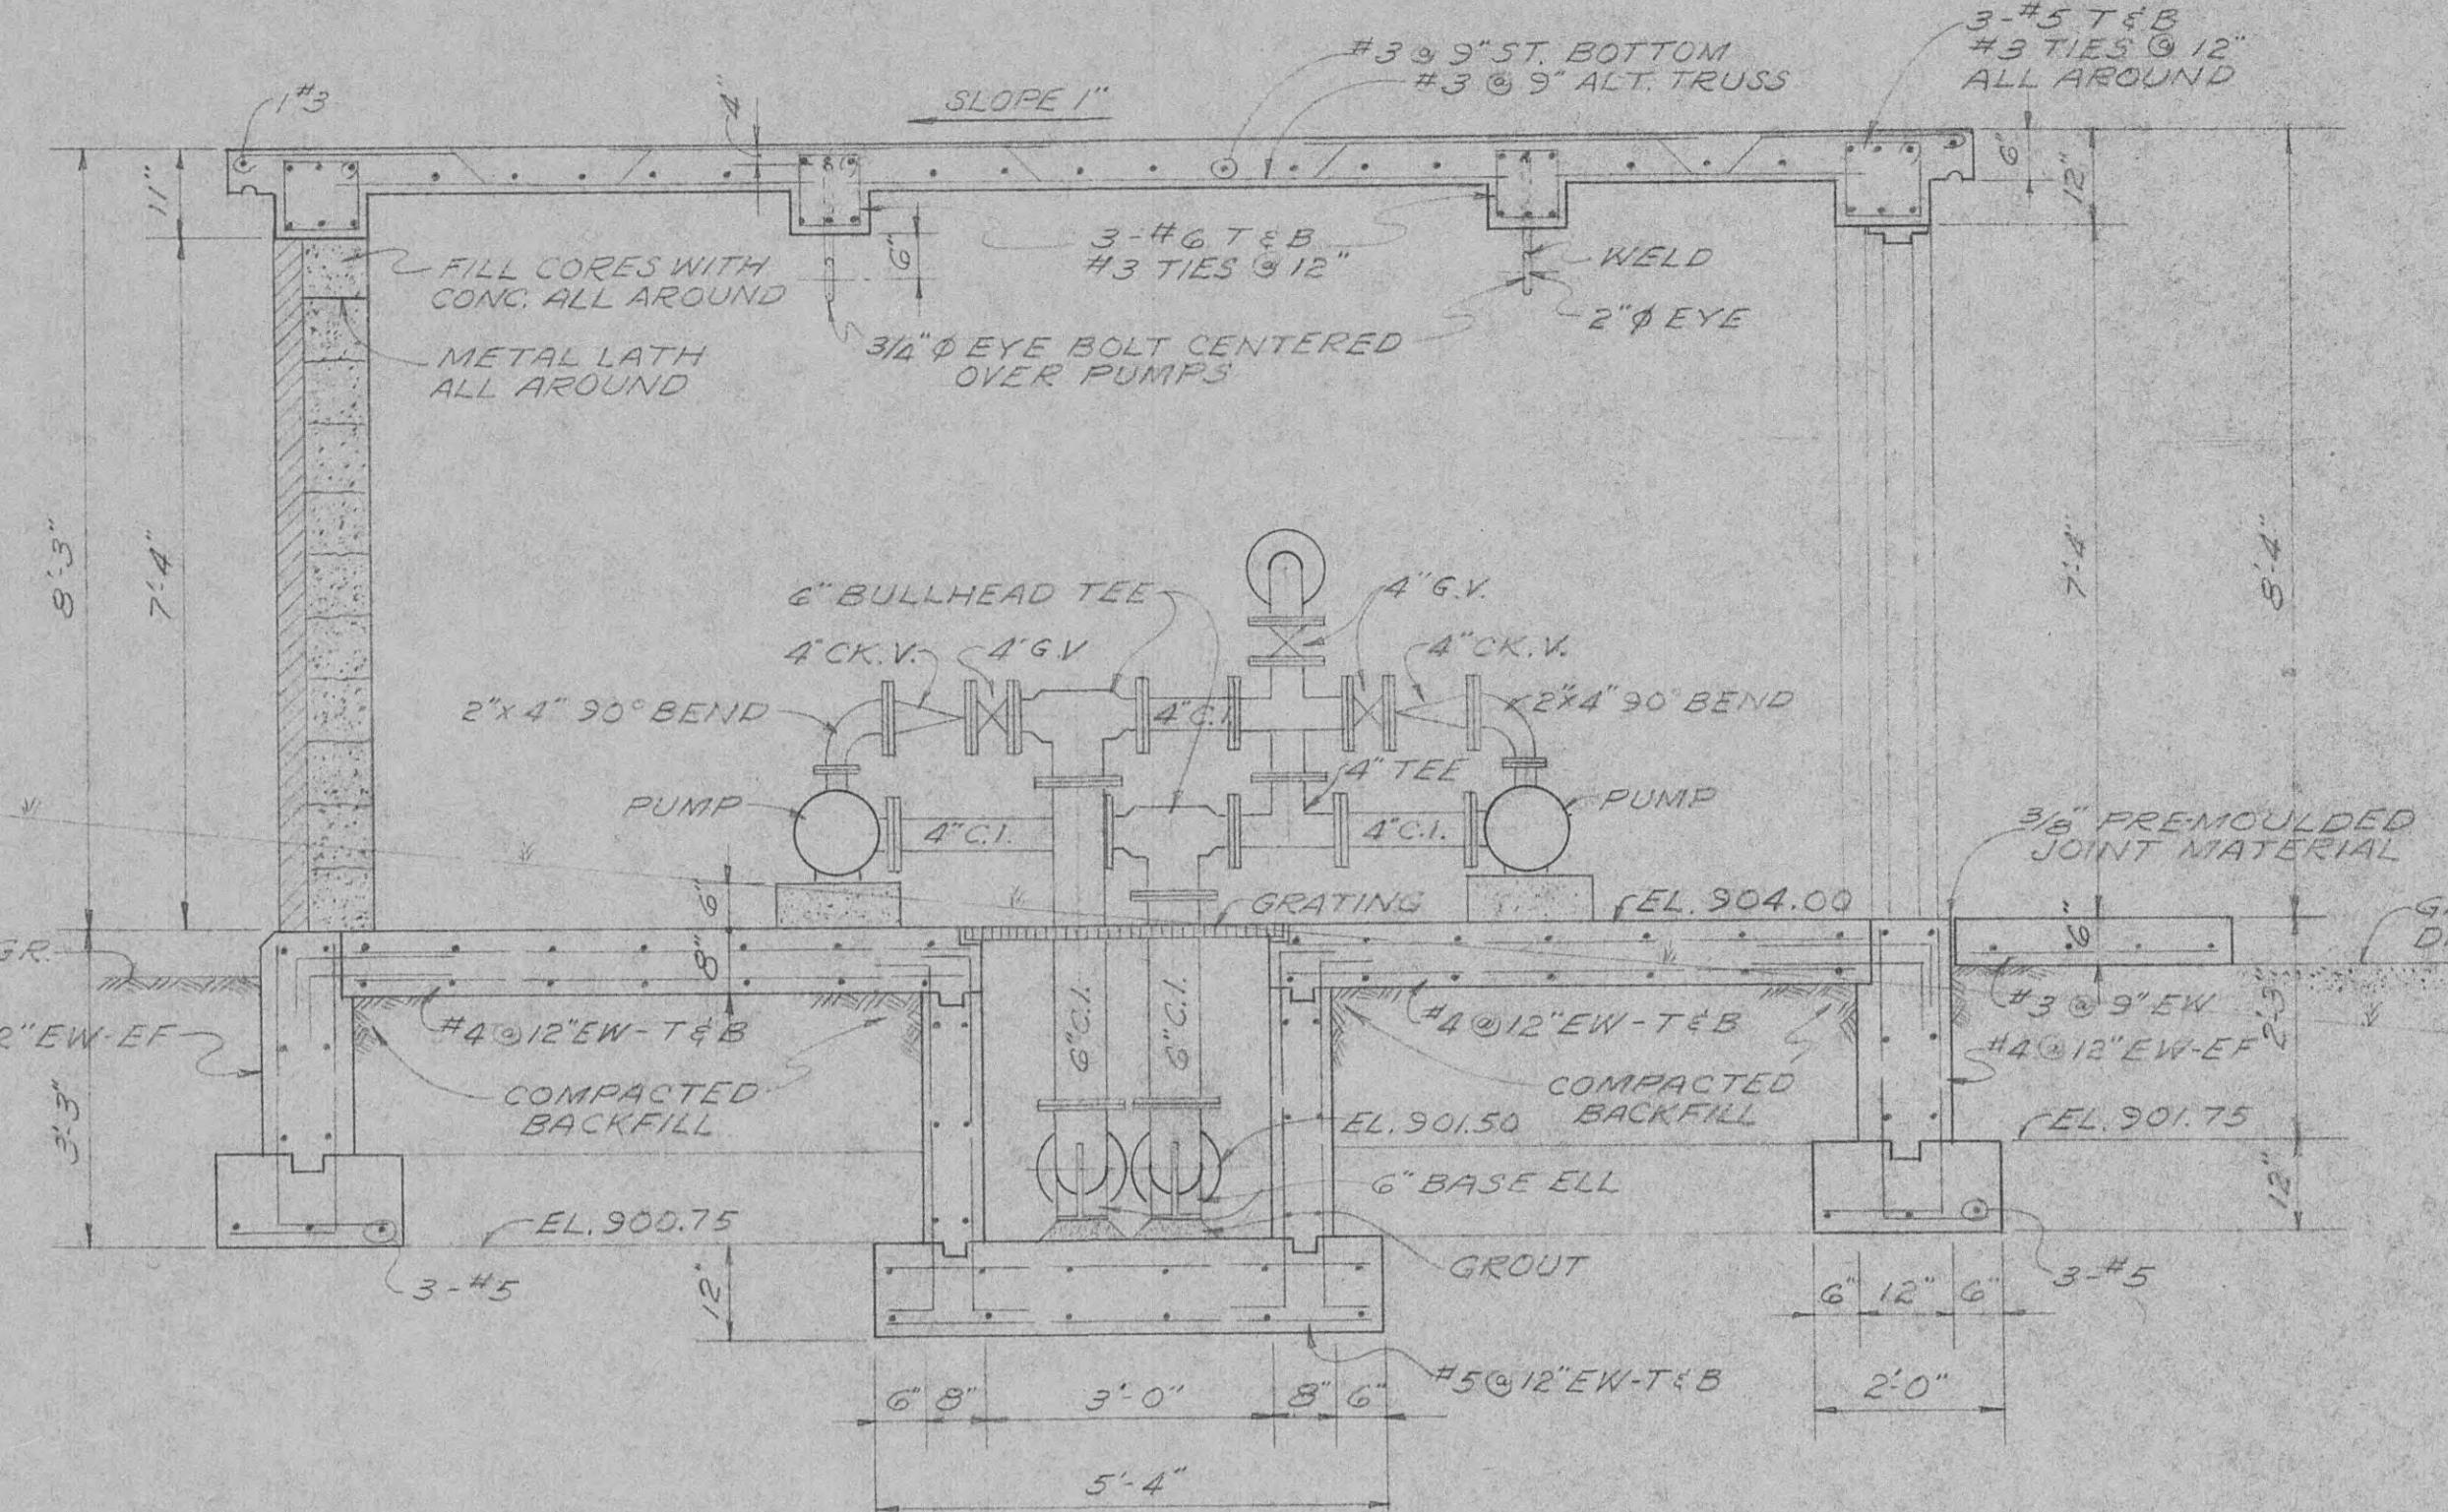


SECTION "A-A"
SCALE: 1/2"=1'-0"

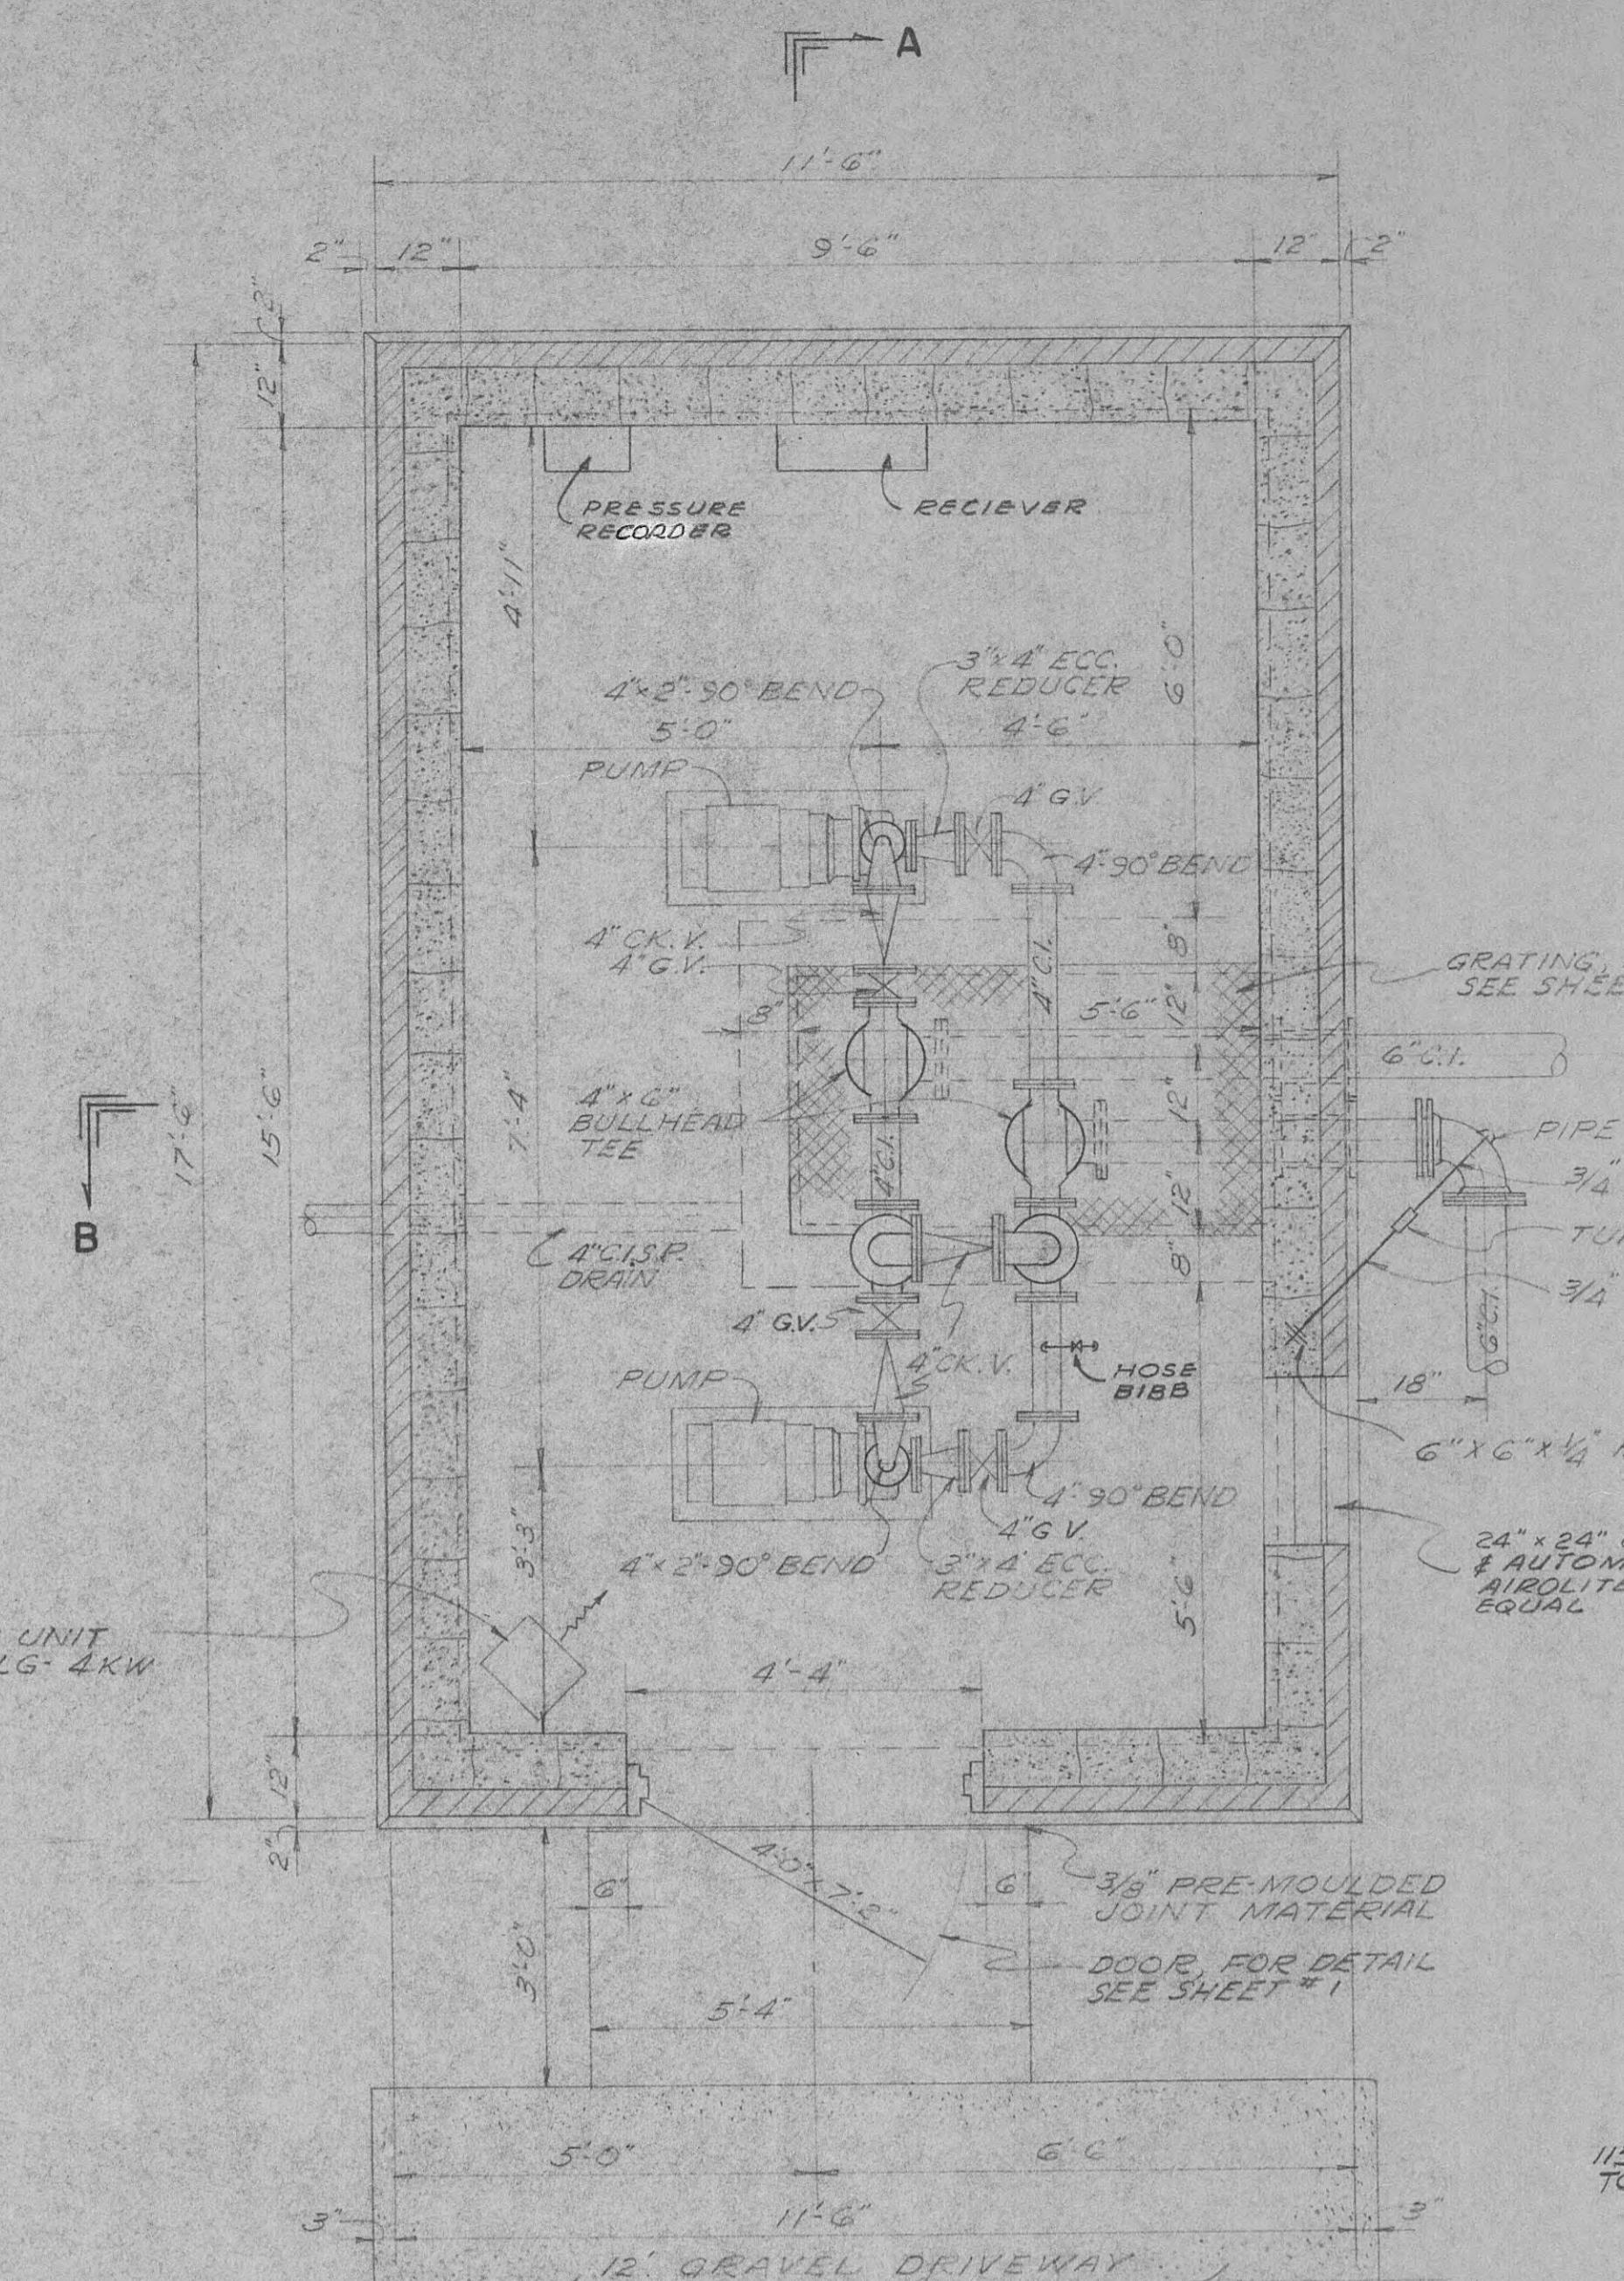


SECTION "B-B"
SCALE: 1/2"=1'-0"

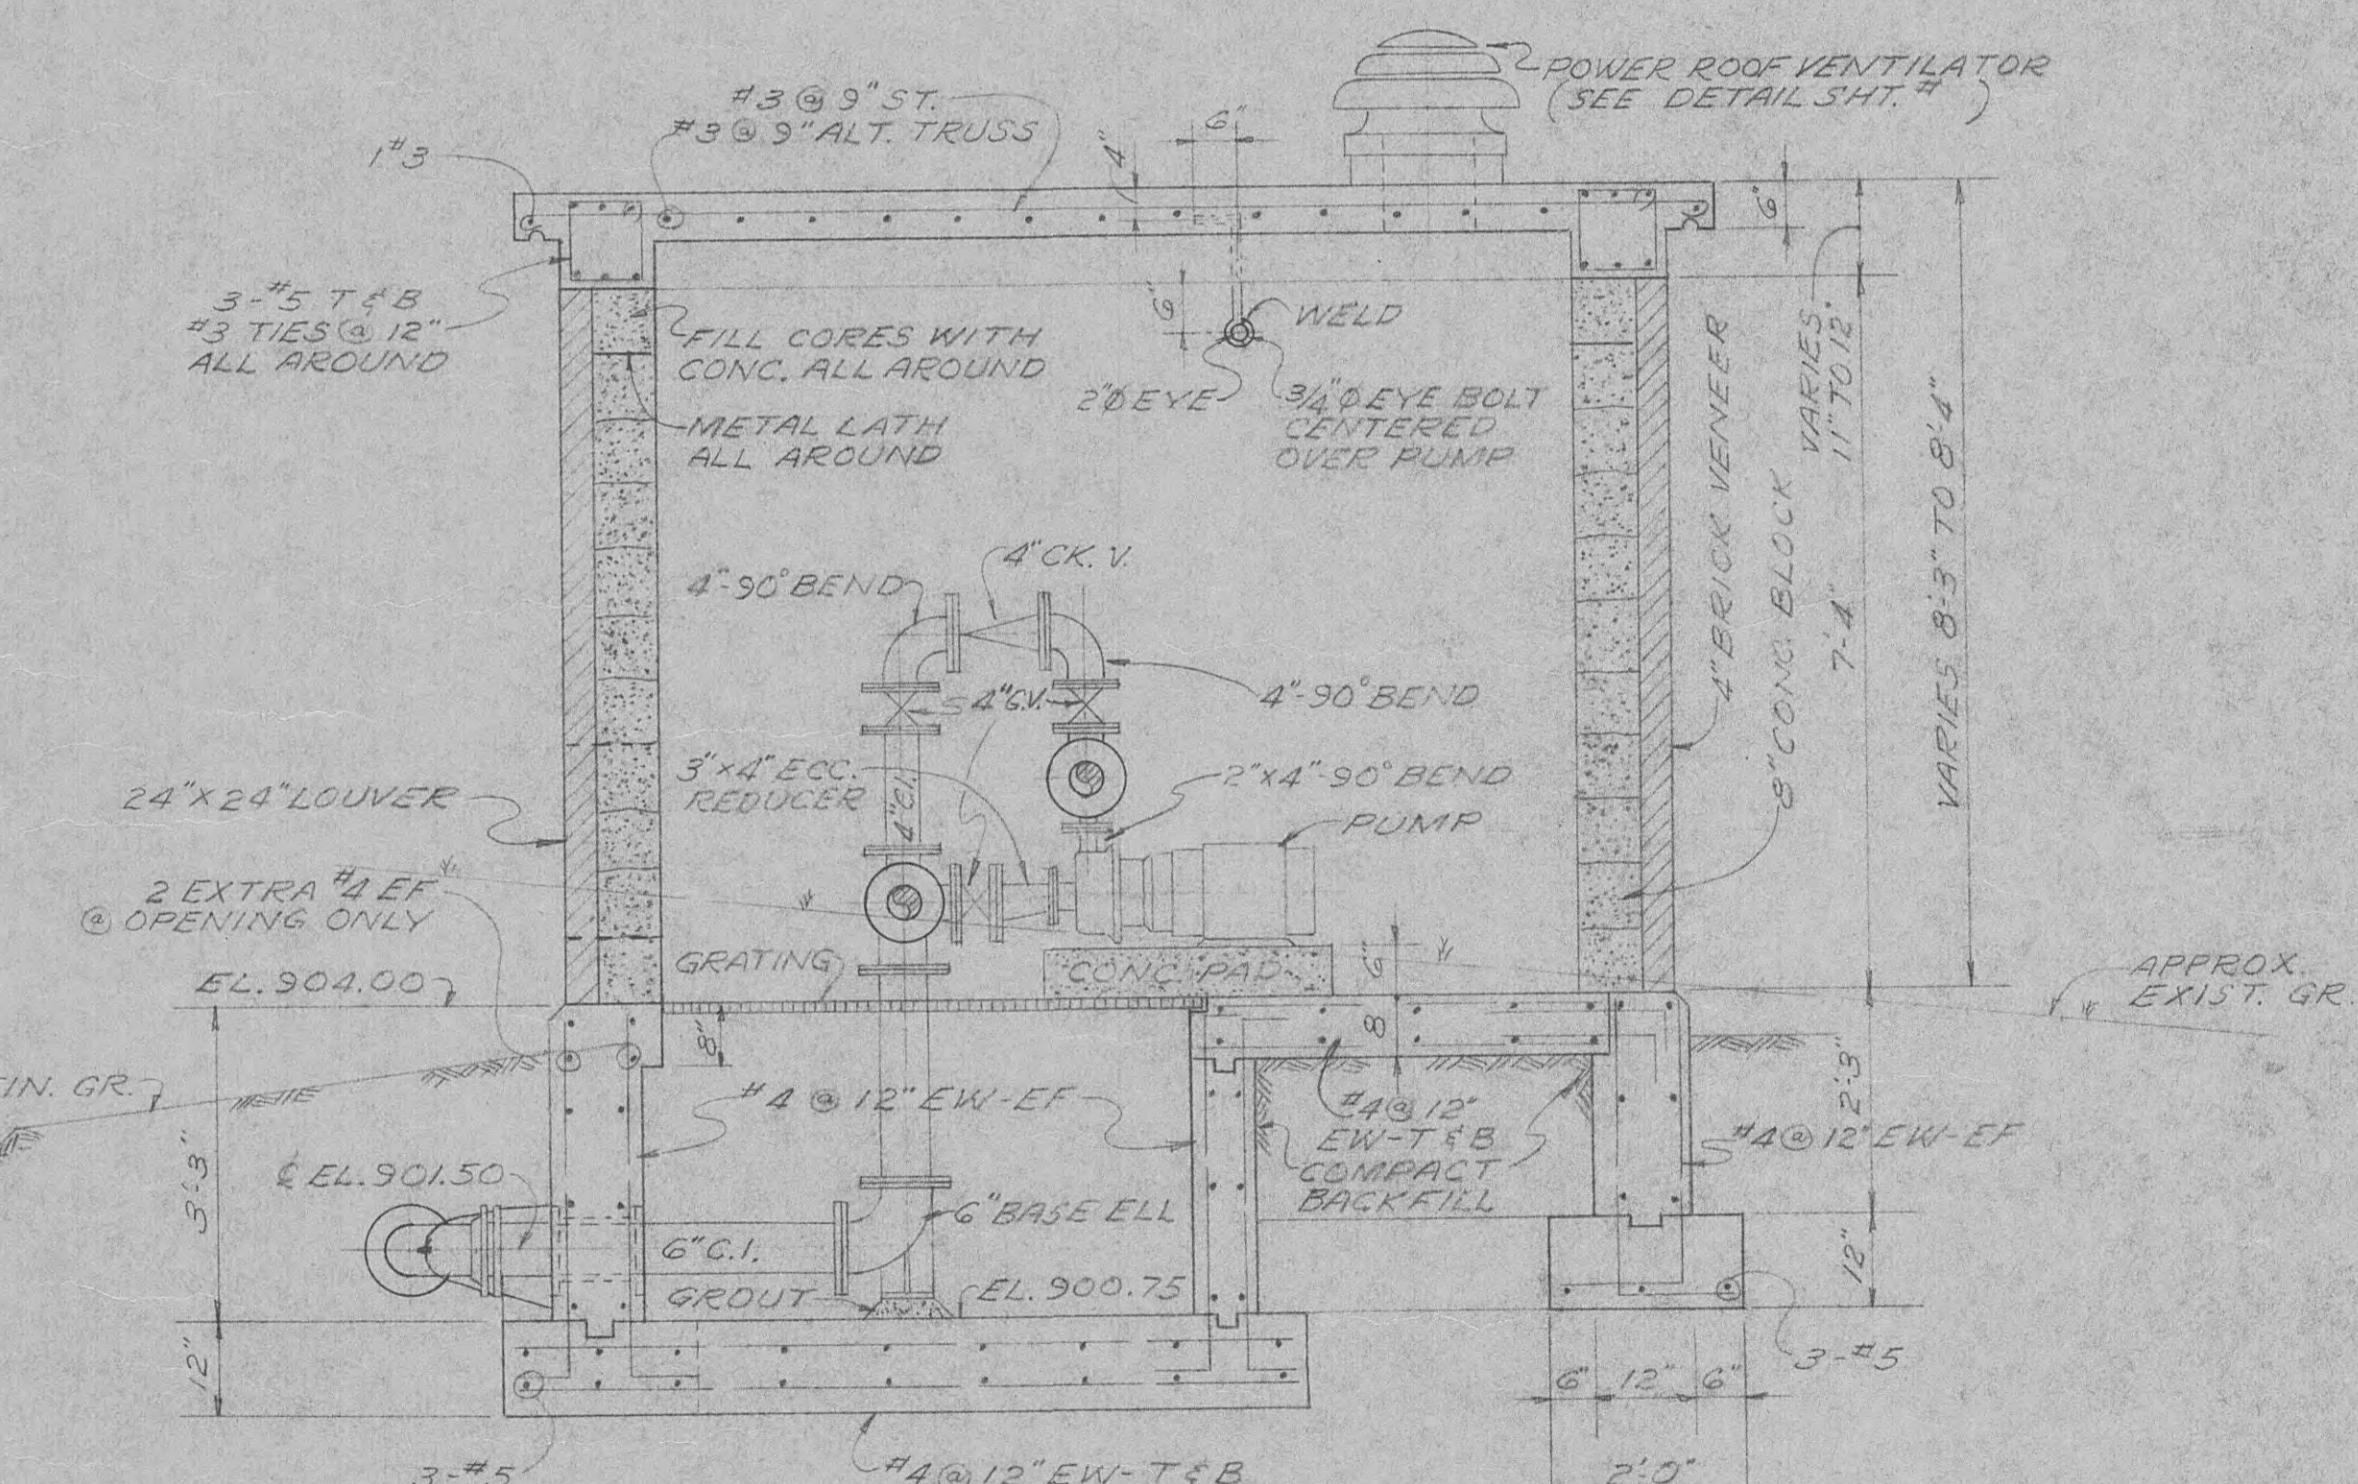


PLAN
SCALE: 1/2"=1'-0"

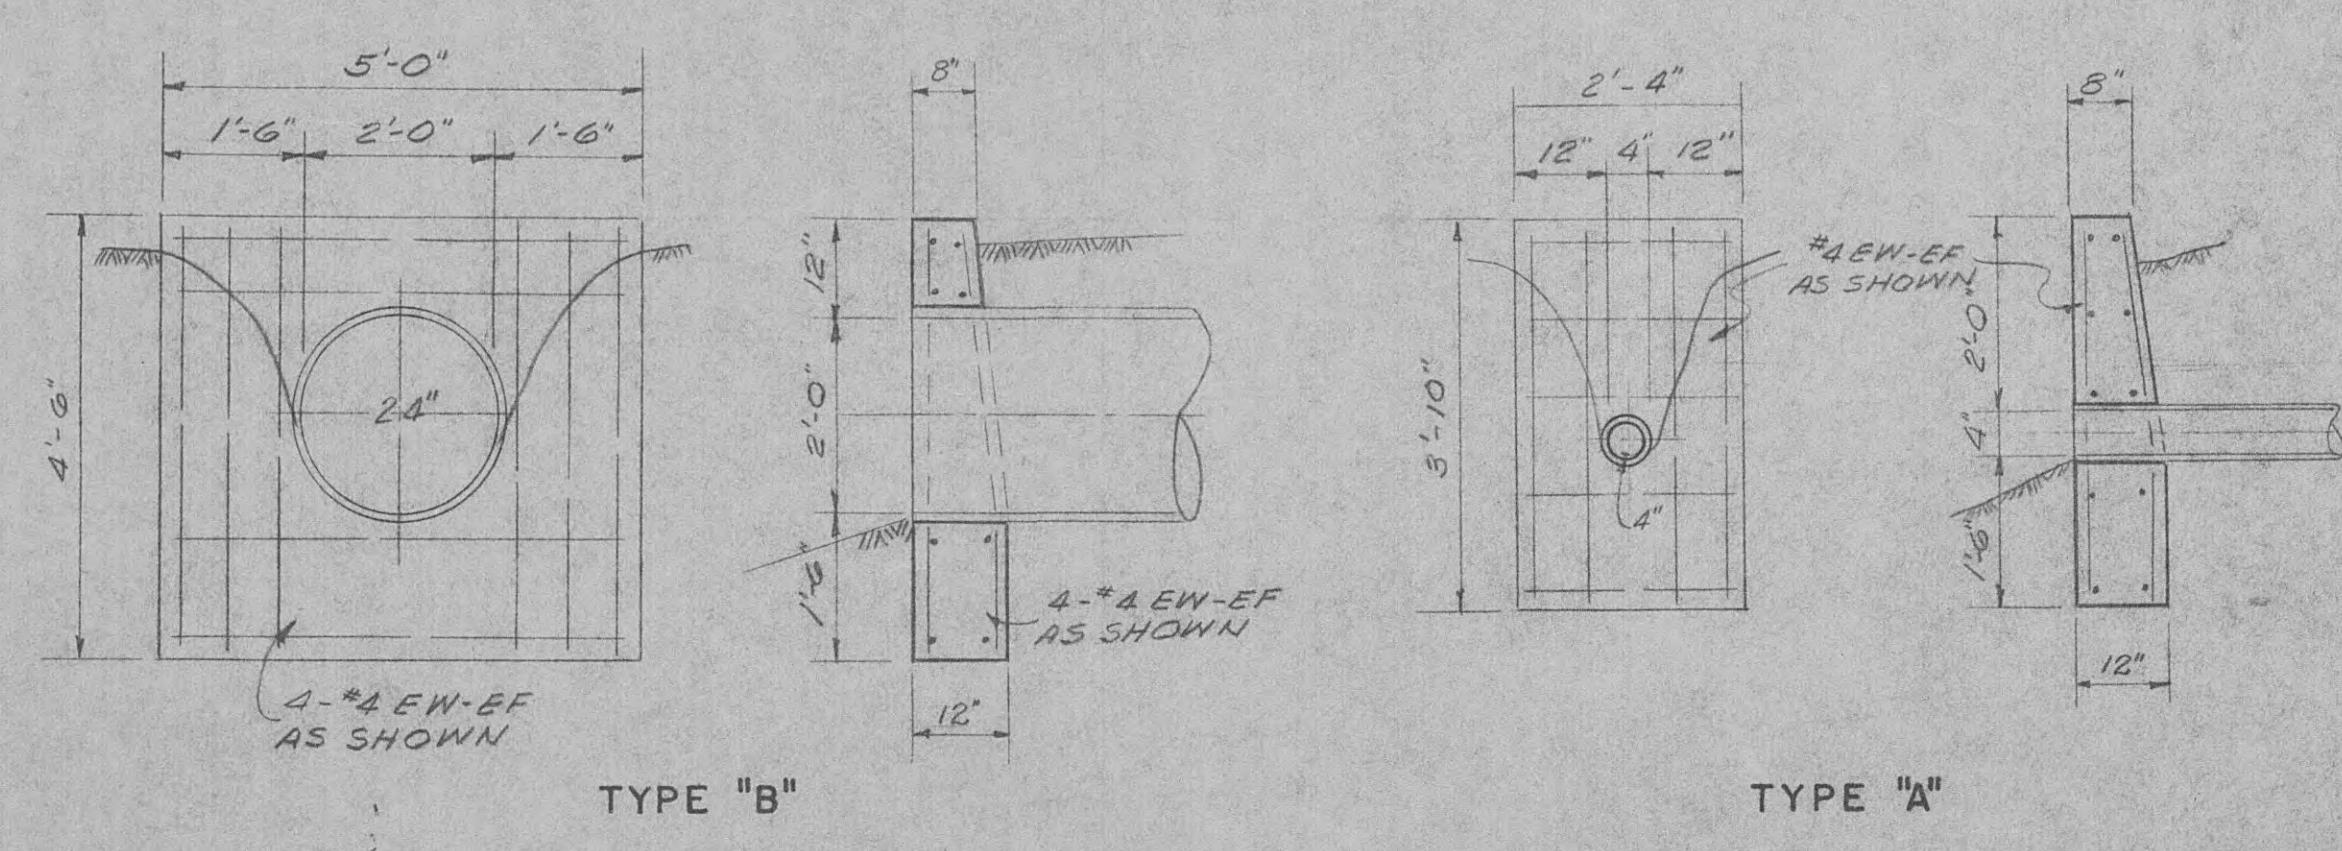

HEADWALL DETAIL
N.T.S.

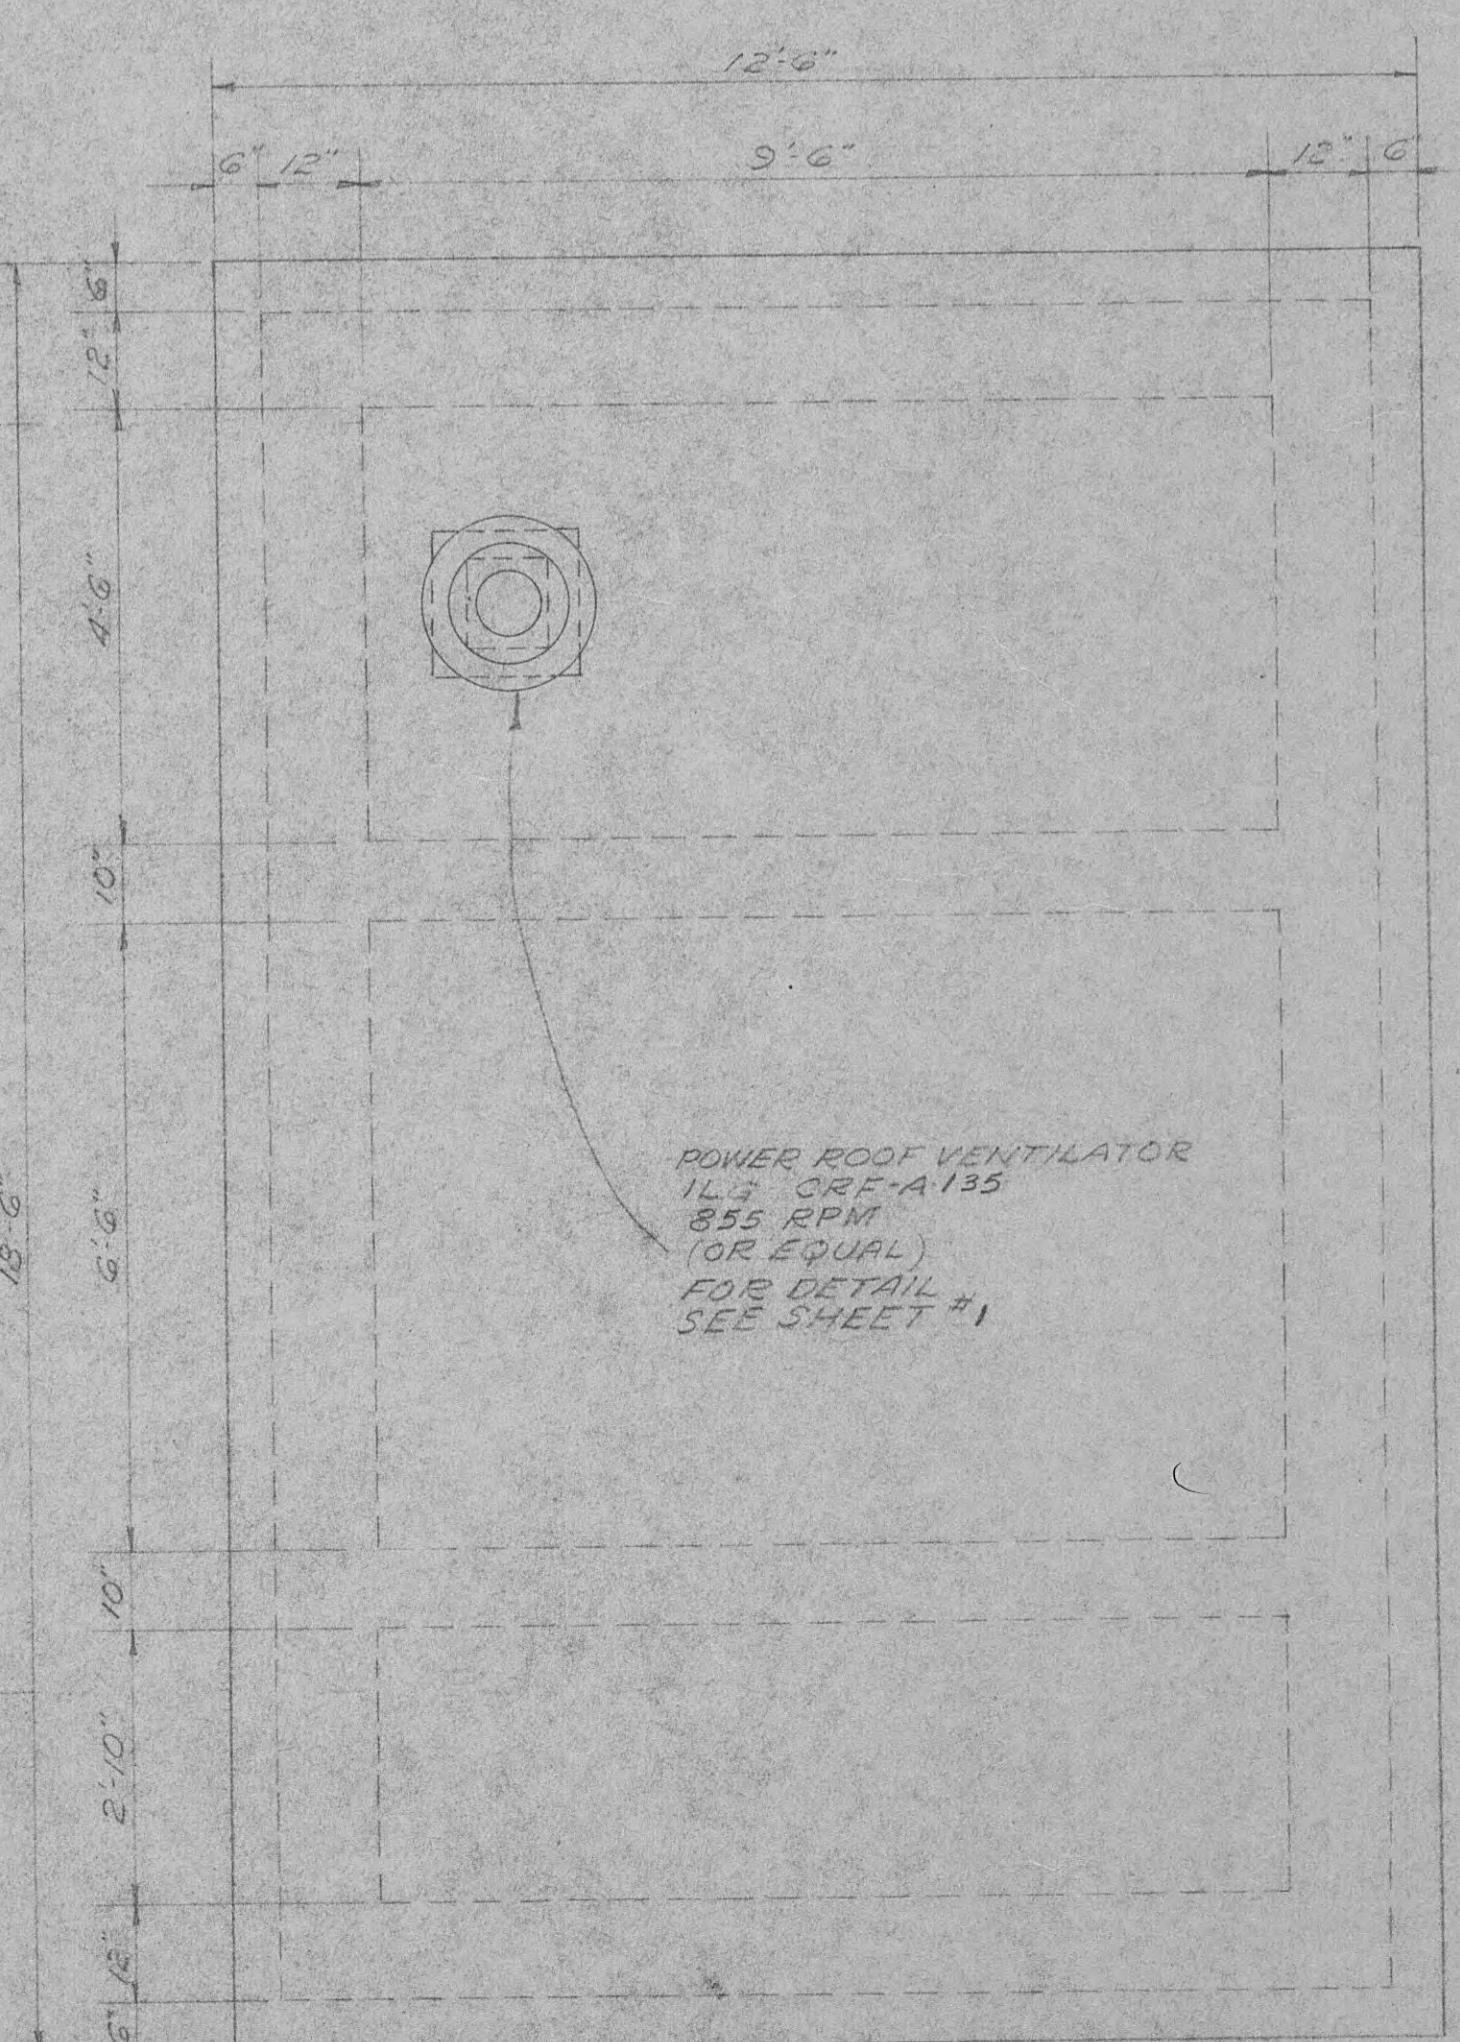

ROOF PLAN
SCALE: 1/2"=1'-0"

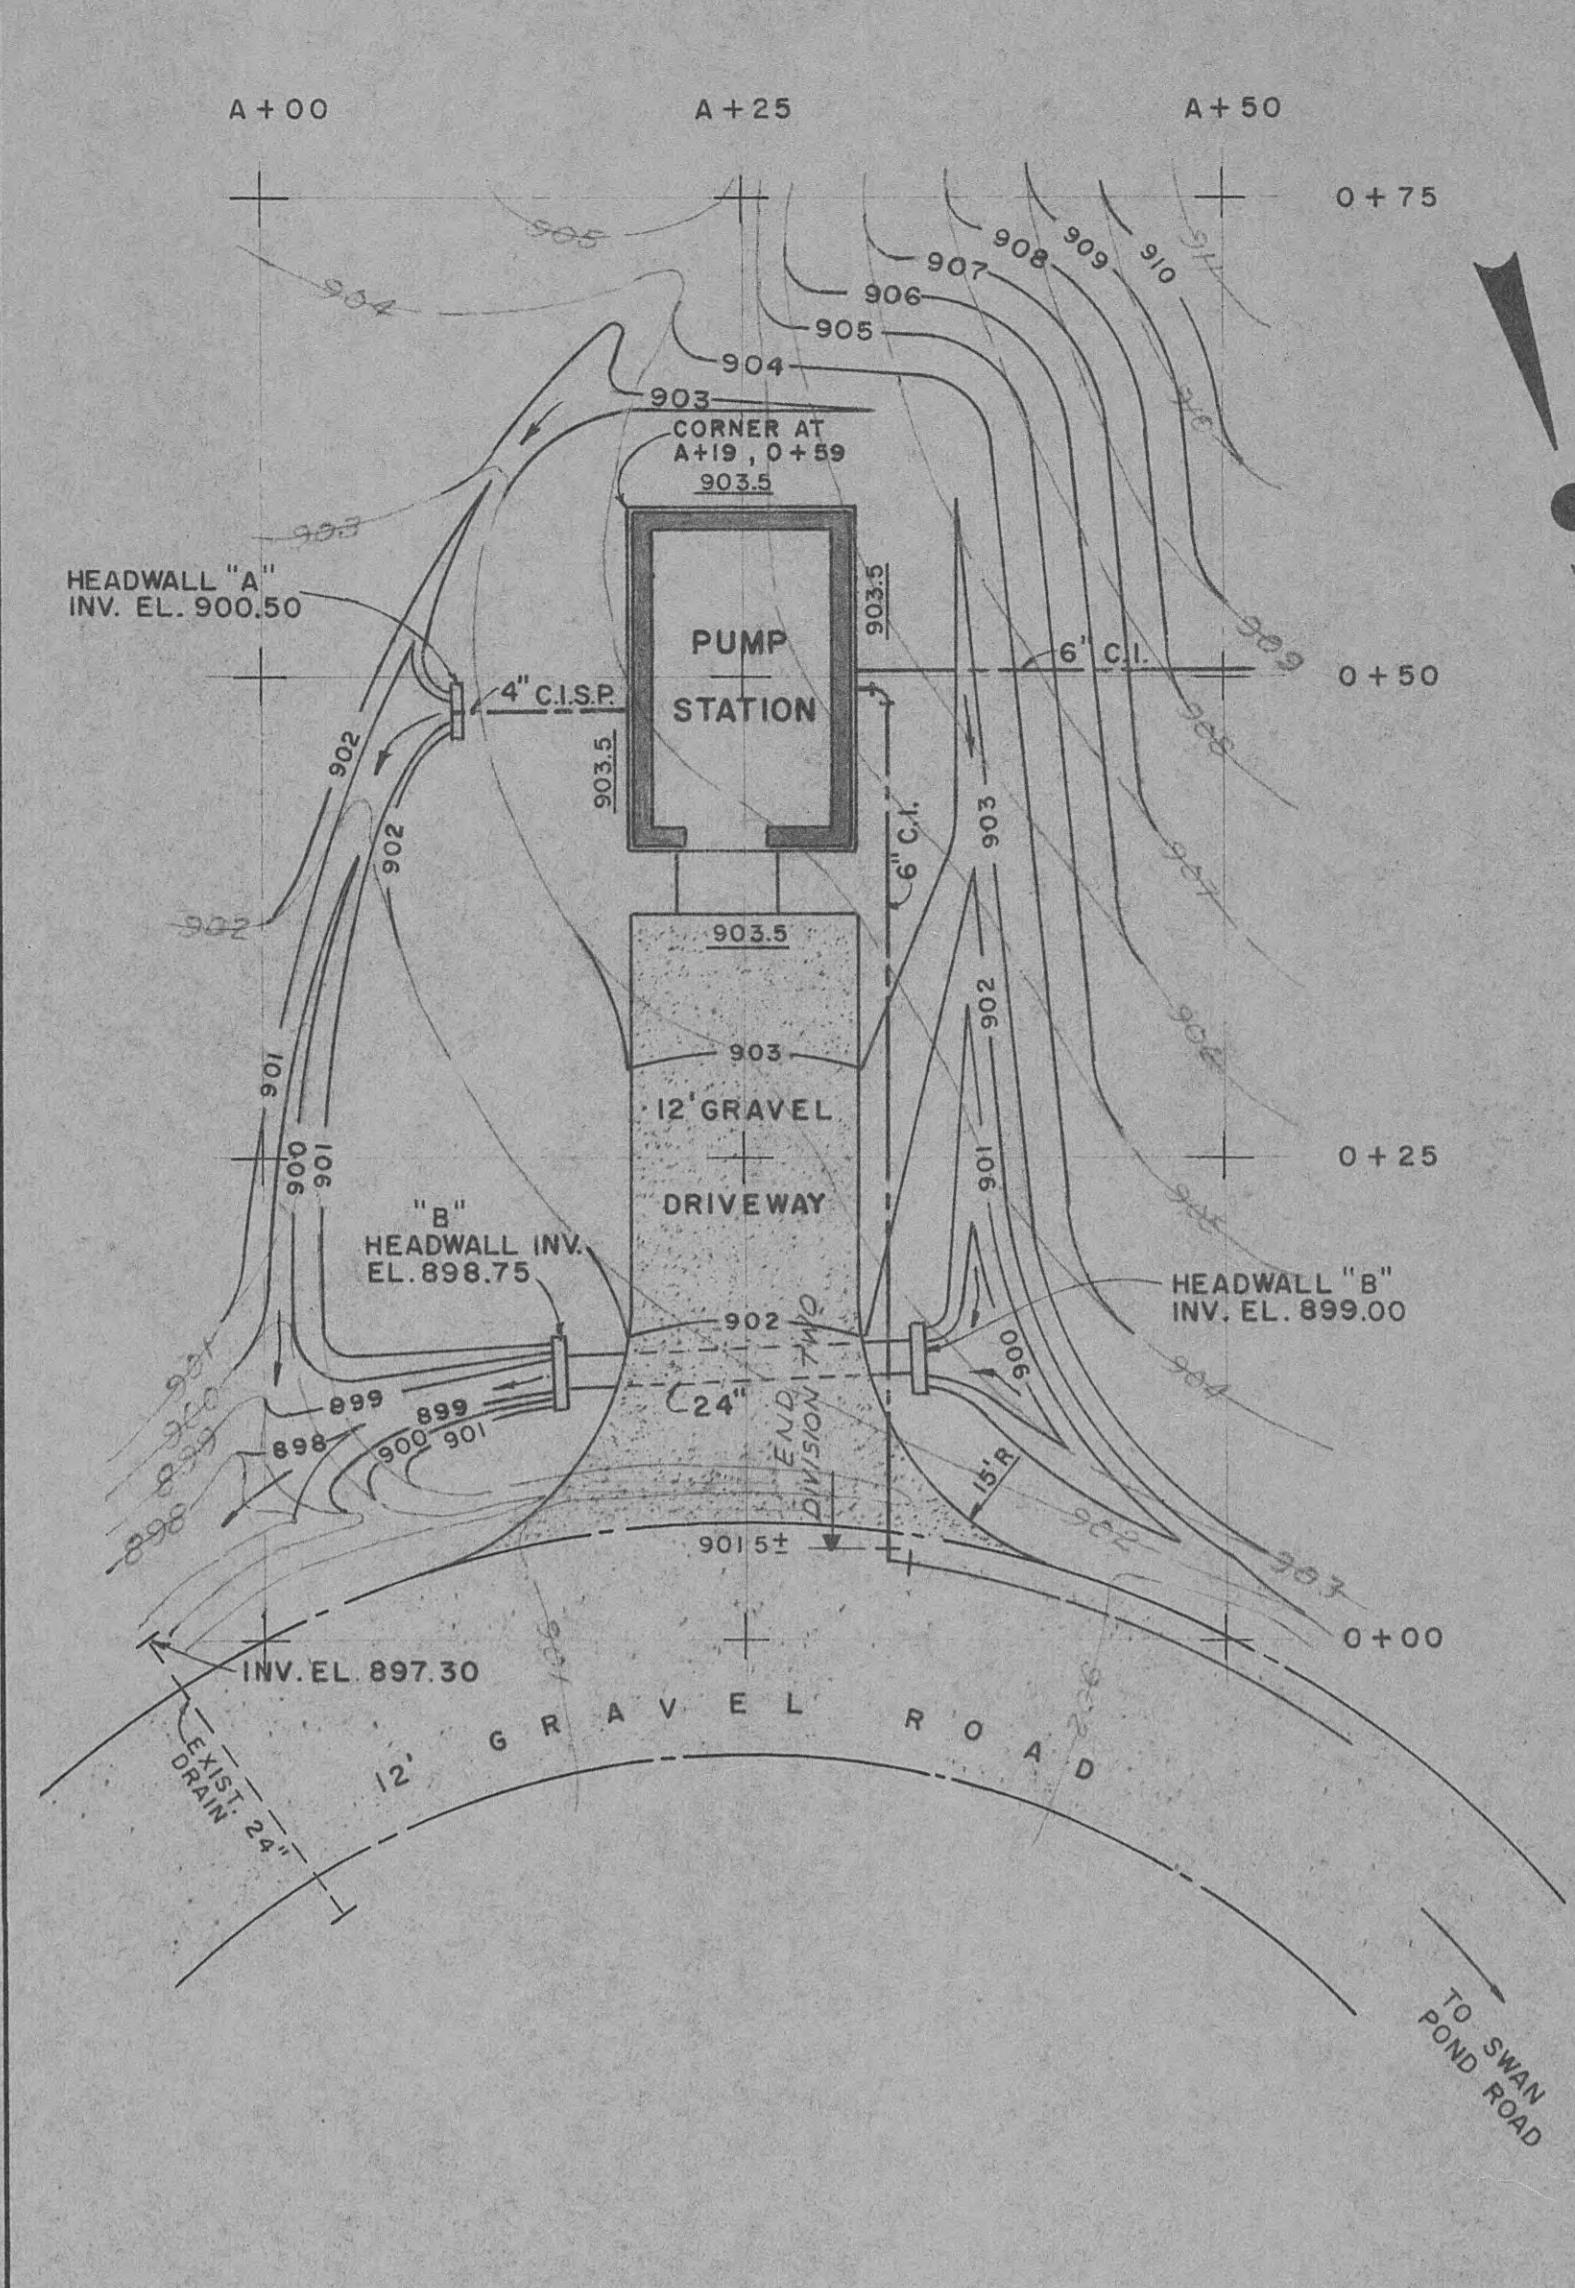


GENERAL LAYOUT
SCALE: 1"=10'

LEGEND

- (A) - CEILING INCANDESCENT, CURTIS-ELECTRO #25514, 150W
- (B) - VAPOLIGHT INCANDESCENT, CROUSE-HINDS # VK HB 15
- (J) - OUTLET BOX USED AS JUNCTION BOX
- (①) - 4 KW UNIT HEATER ILG 4615 & CONTROL ILG 7321
- (②) - DUPLEX RECEPTACLE, 4" O.D. HUBBELL #5252
- (S) - SINGLE POLE SWITCH, 4" O.D. HUBBELL #1201
- (W) - WIRING EXPOSED IN RIGID CONDUIT
- (H) - WIRING CONCEALED IN CONCRETE (RIGID)
- (B) - BRANCH CIRCUIT HOMERUN (TYPE BHW WIRE)
- (VS) - MOTOR WITH TERMINAL COMPARTMENT SIZE AS NOTED
- (P) - POWER DRAFTING, SOURCE CENTER, GET PAP, PMCL-1 OR EQUAL 150A-3P 250V 30A 4W, NEMA-1, WITH QBS
- (1) - 150A-3P MAIN CB
- (6-82A) - 1P CB'S USE
- (6-82A-3PCB) - 3PCB UNIT HEATER
- (2-51Z) - COMBINATION PUMP STARTERS WITH H-O-A SWITCHES & RED RUN LIGHT

NOTE ON OPERATION

TELEPHONE SIGNAL TO RECEIVER ACTUATES ON-OFF SWITCH IN RECEIVER, ENERGIZING MAGNETIC MOTOR STARTING SWITCH FOR EACH PUMP SEPARATELY.

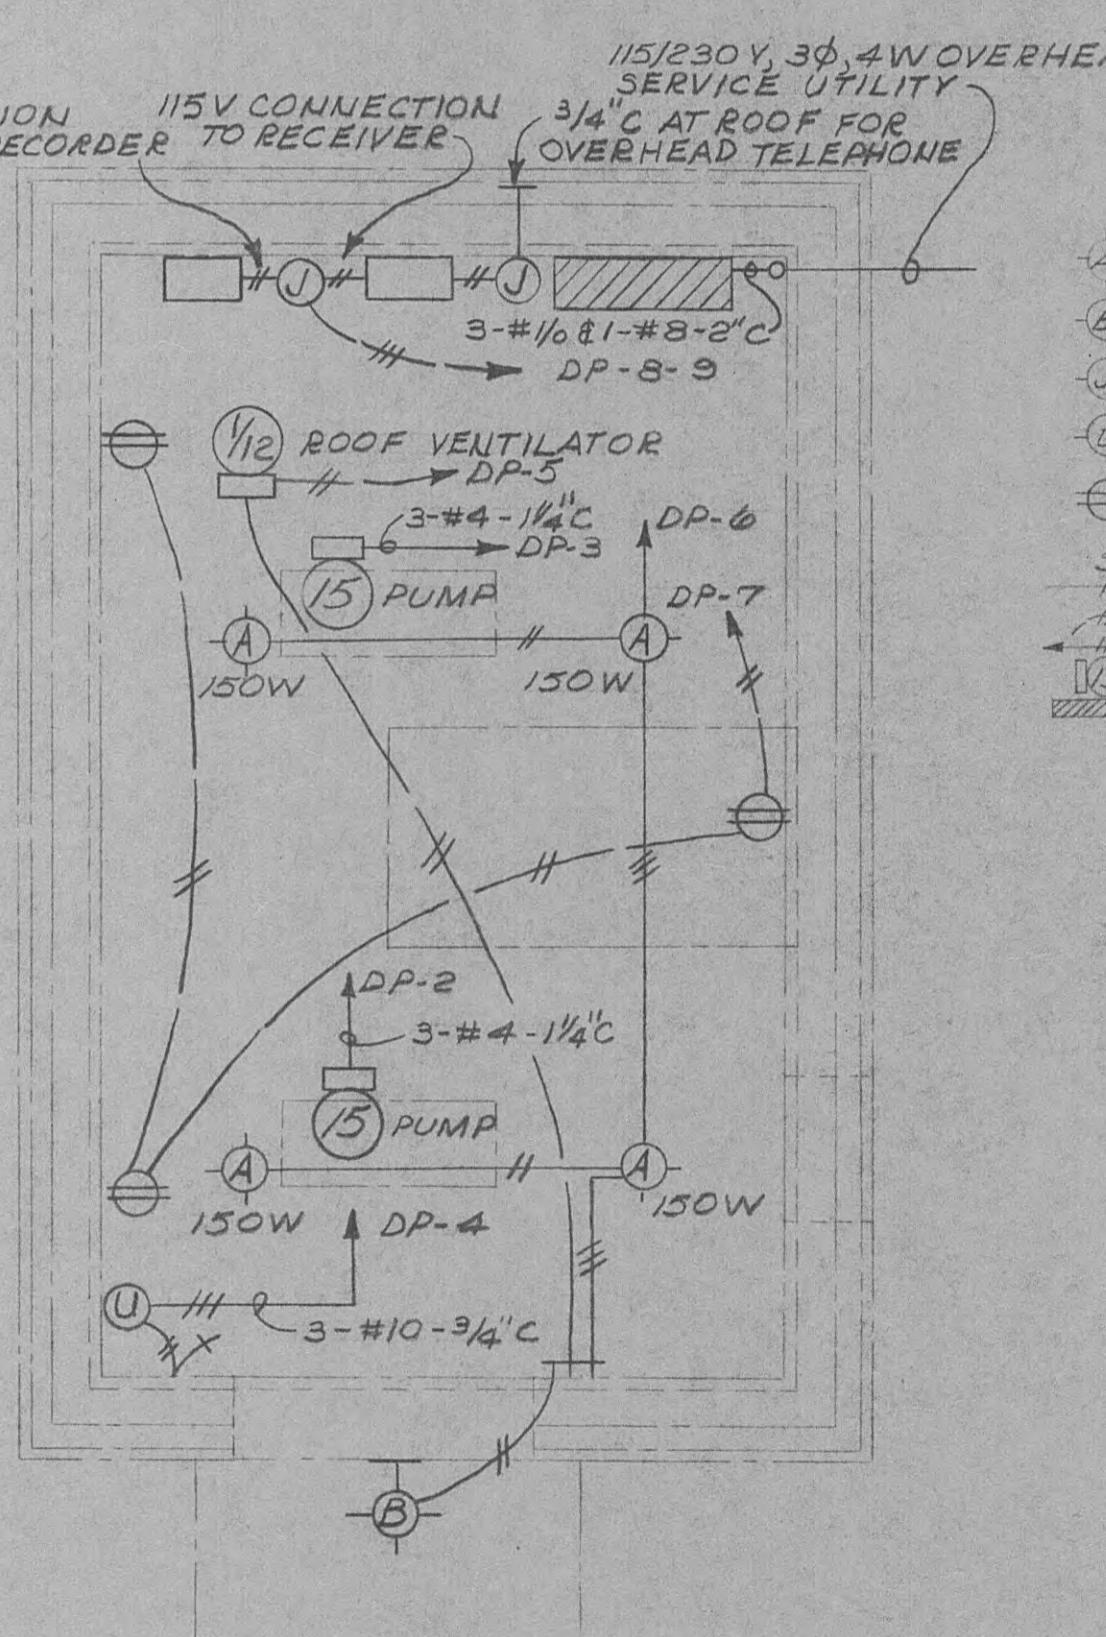

ELECTRICAL PLAN
SCALE: 3/8"=1'-0"






DIVISION TWO

CITY OF HARRIMAN, TENNESSEE
WATER SYSTEM IMPROVEMENTS

SWAN POND ROAD
BOOSTER PUMPING STATION




SCALE AS SHOWN
DATE MAY, 1966
ATLANTA, GEORGIA


SHEET 2
OF 5

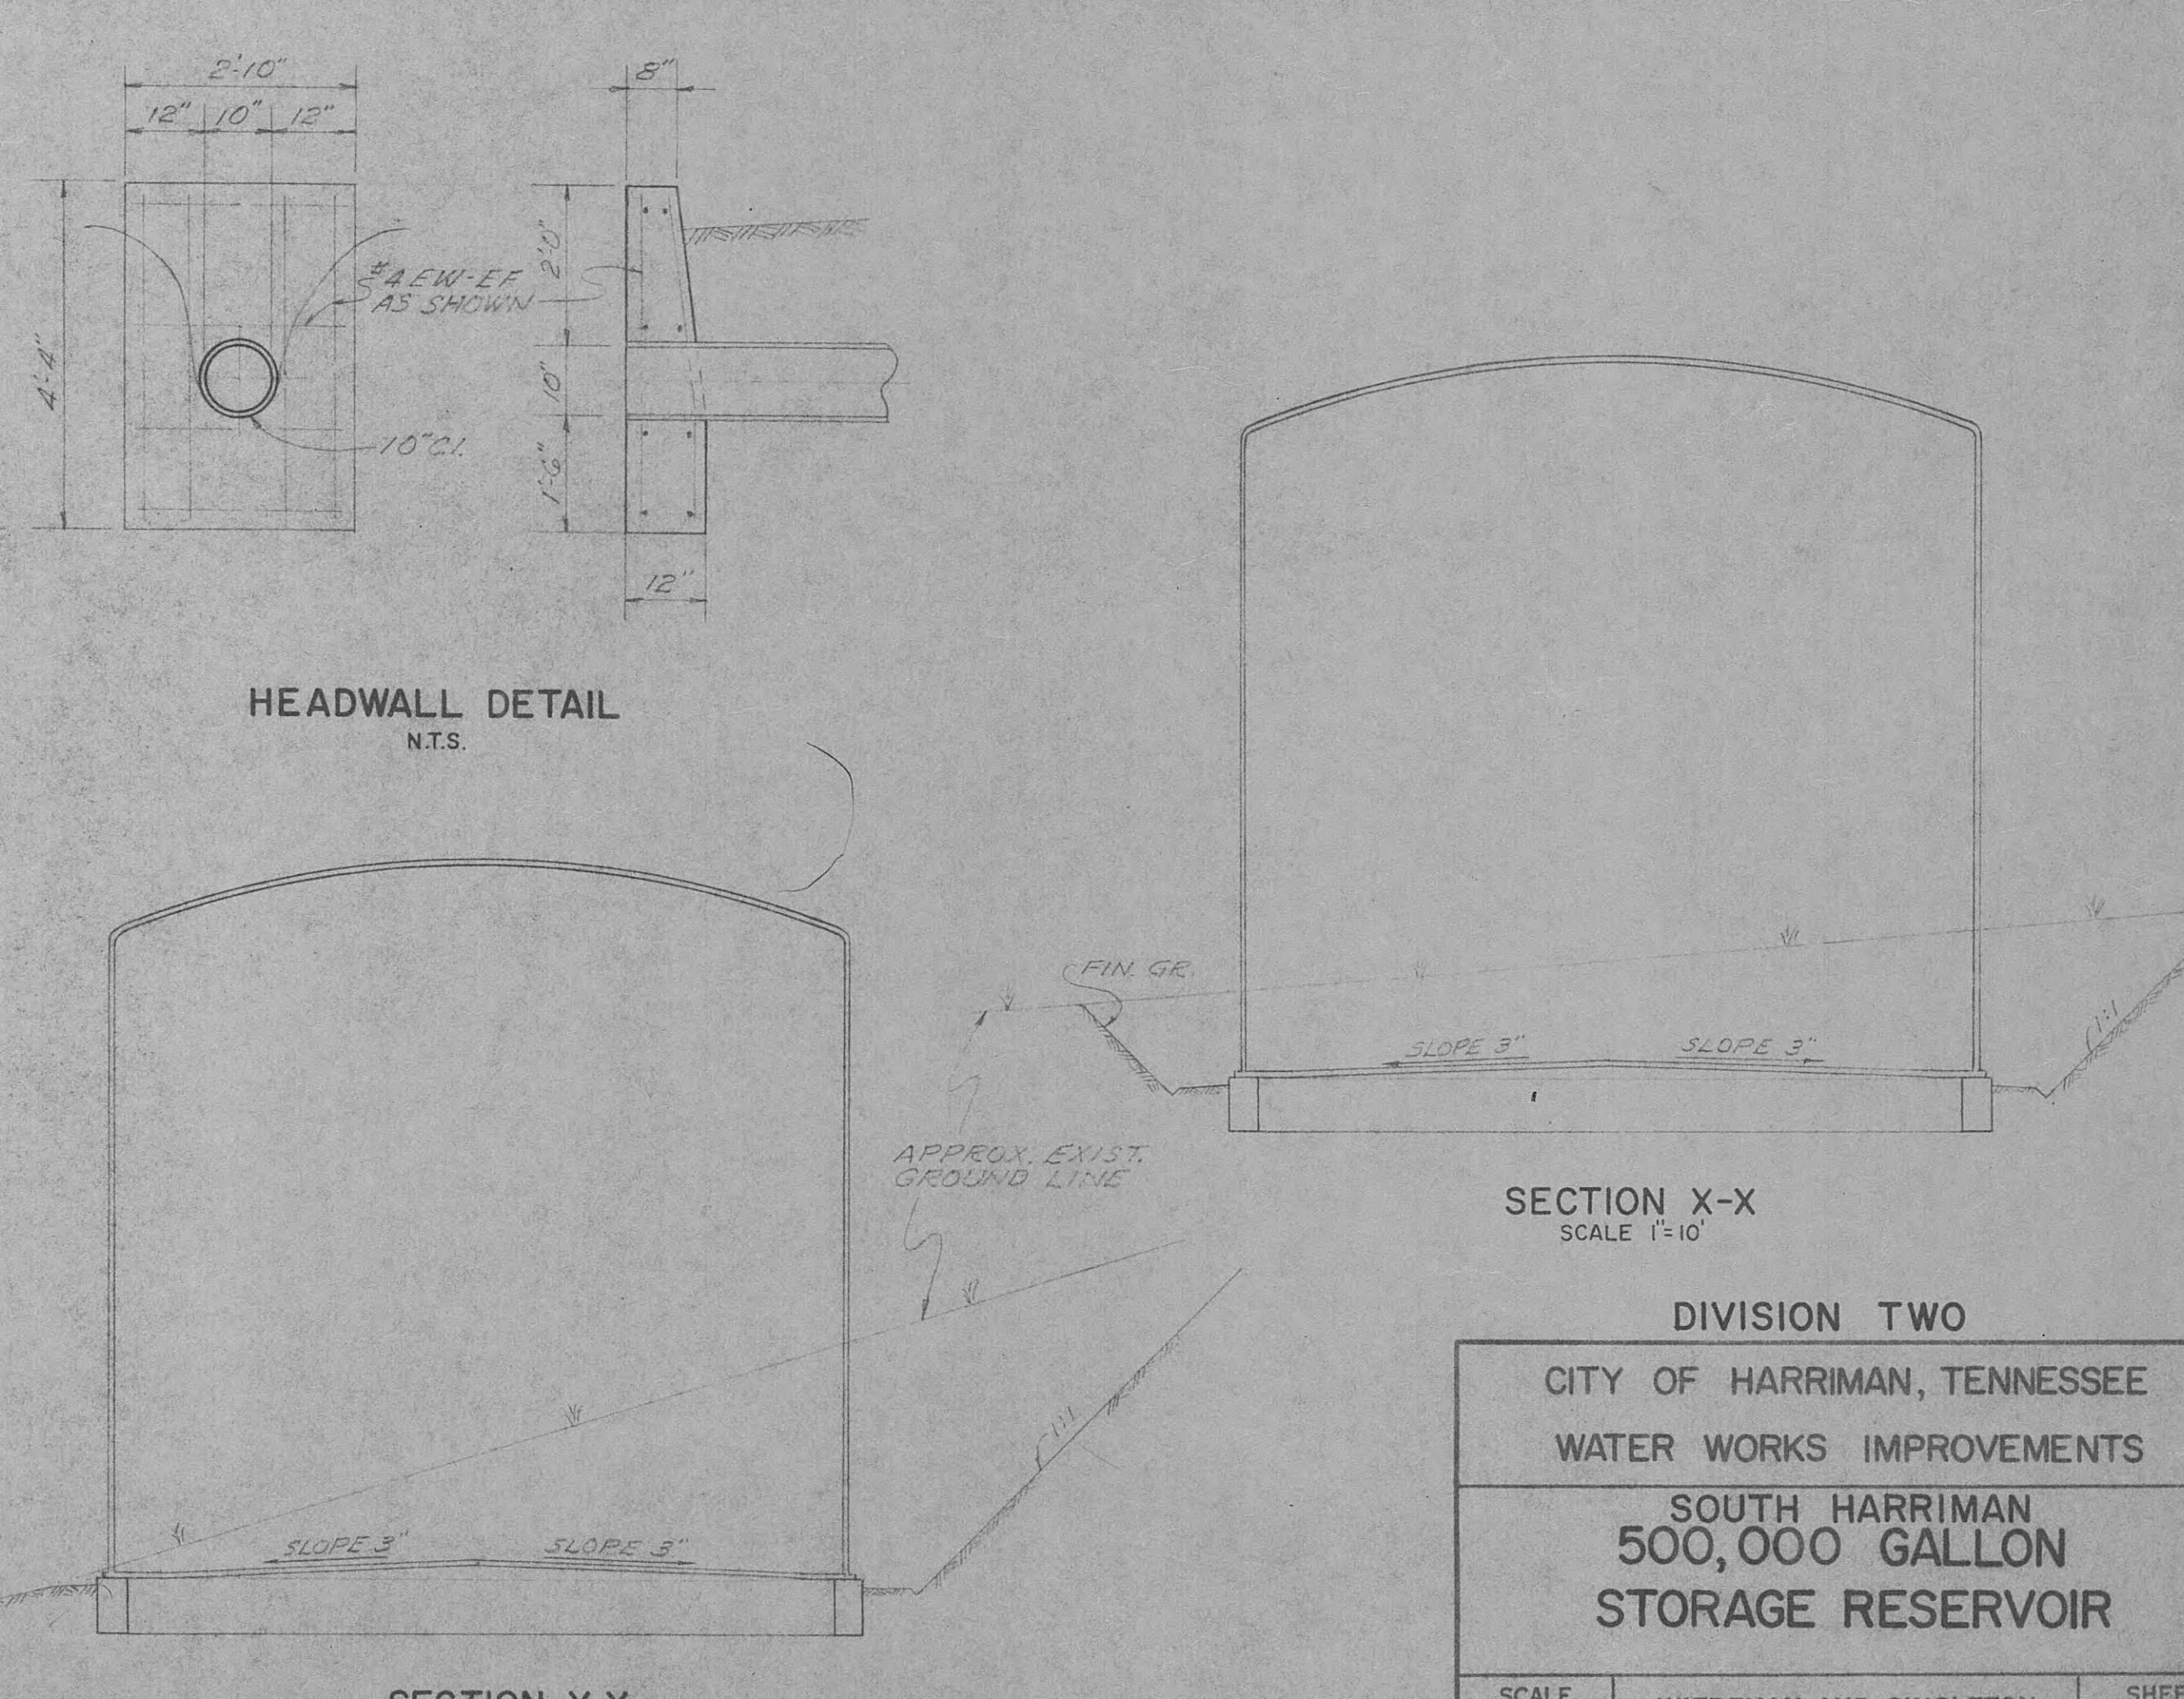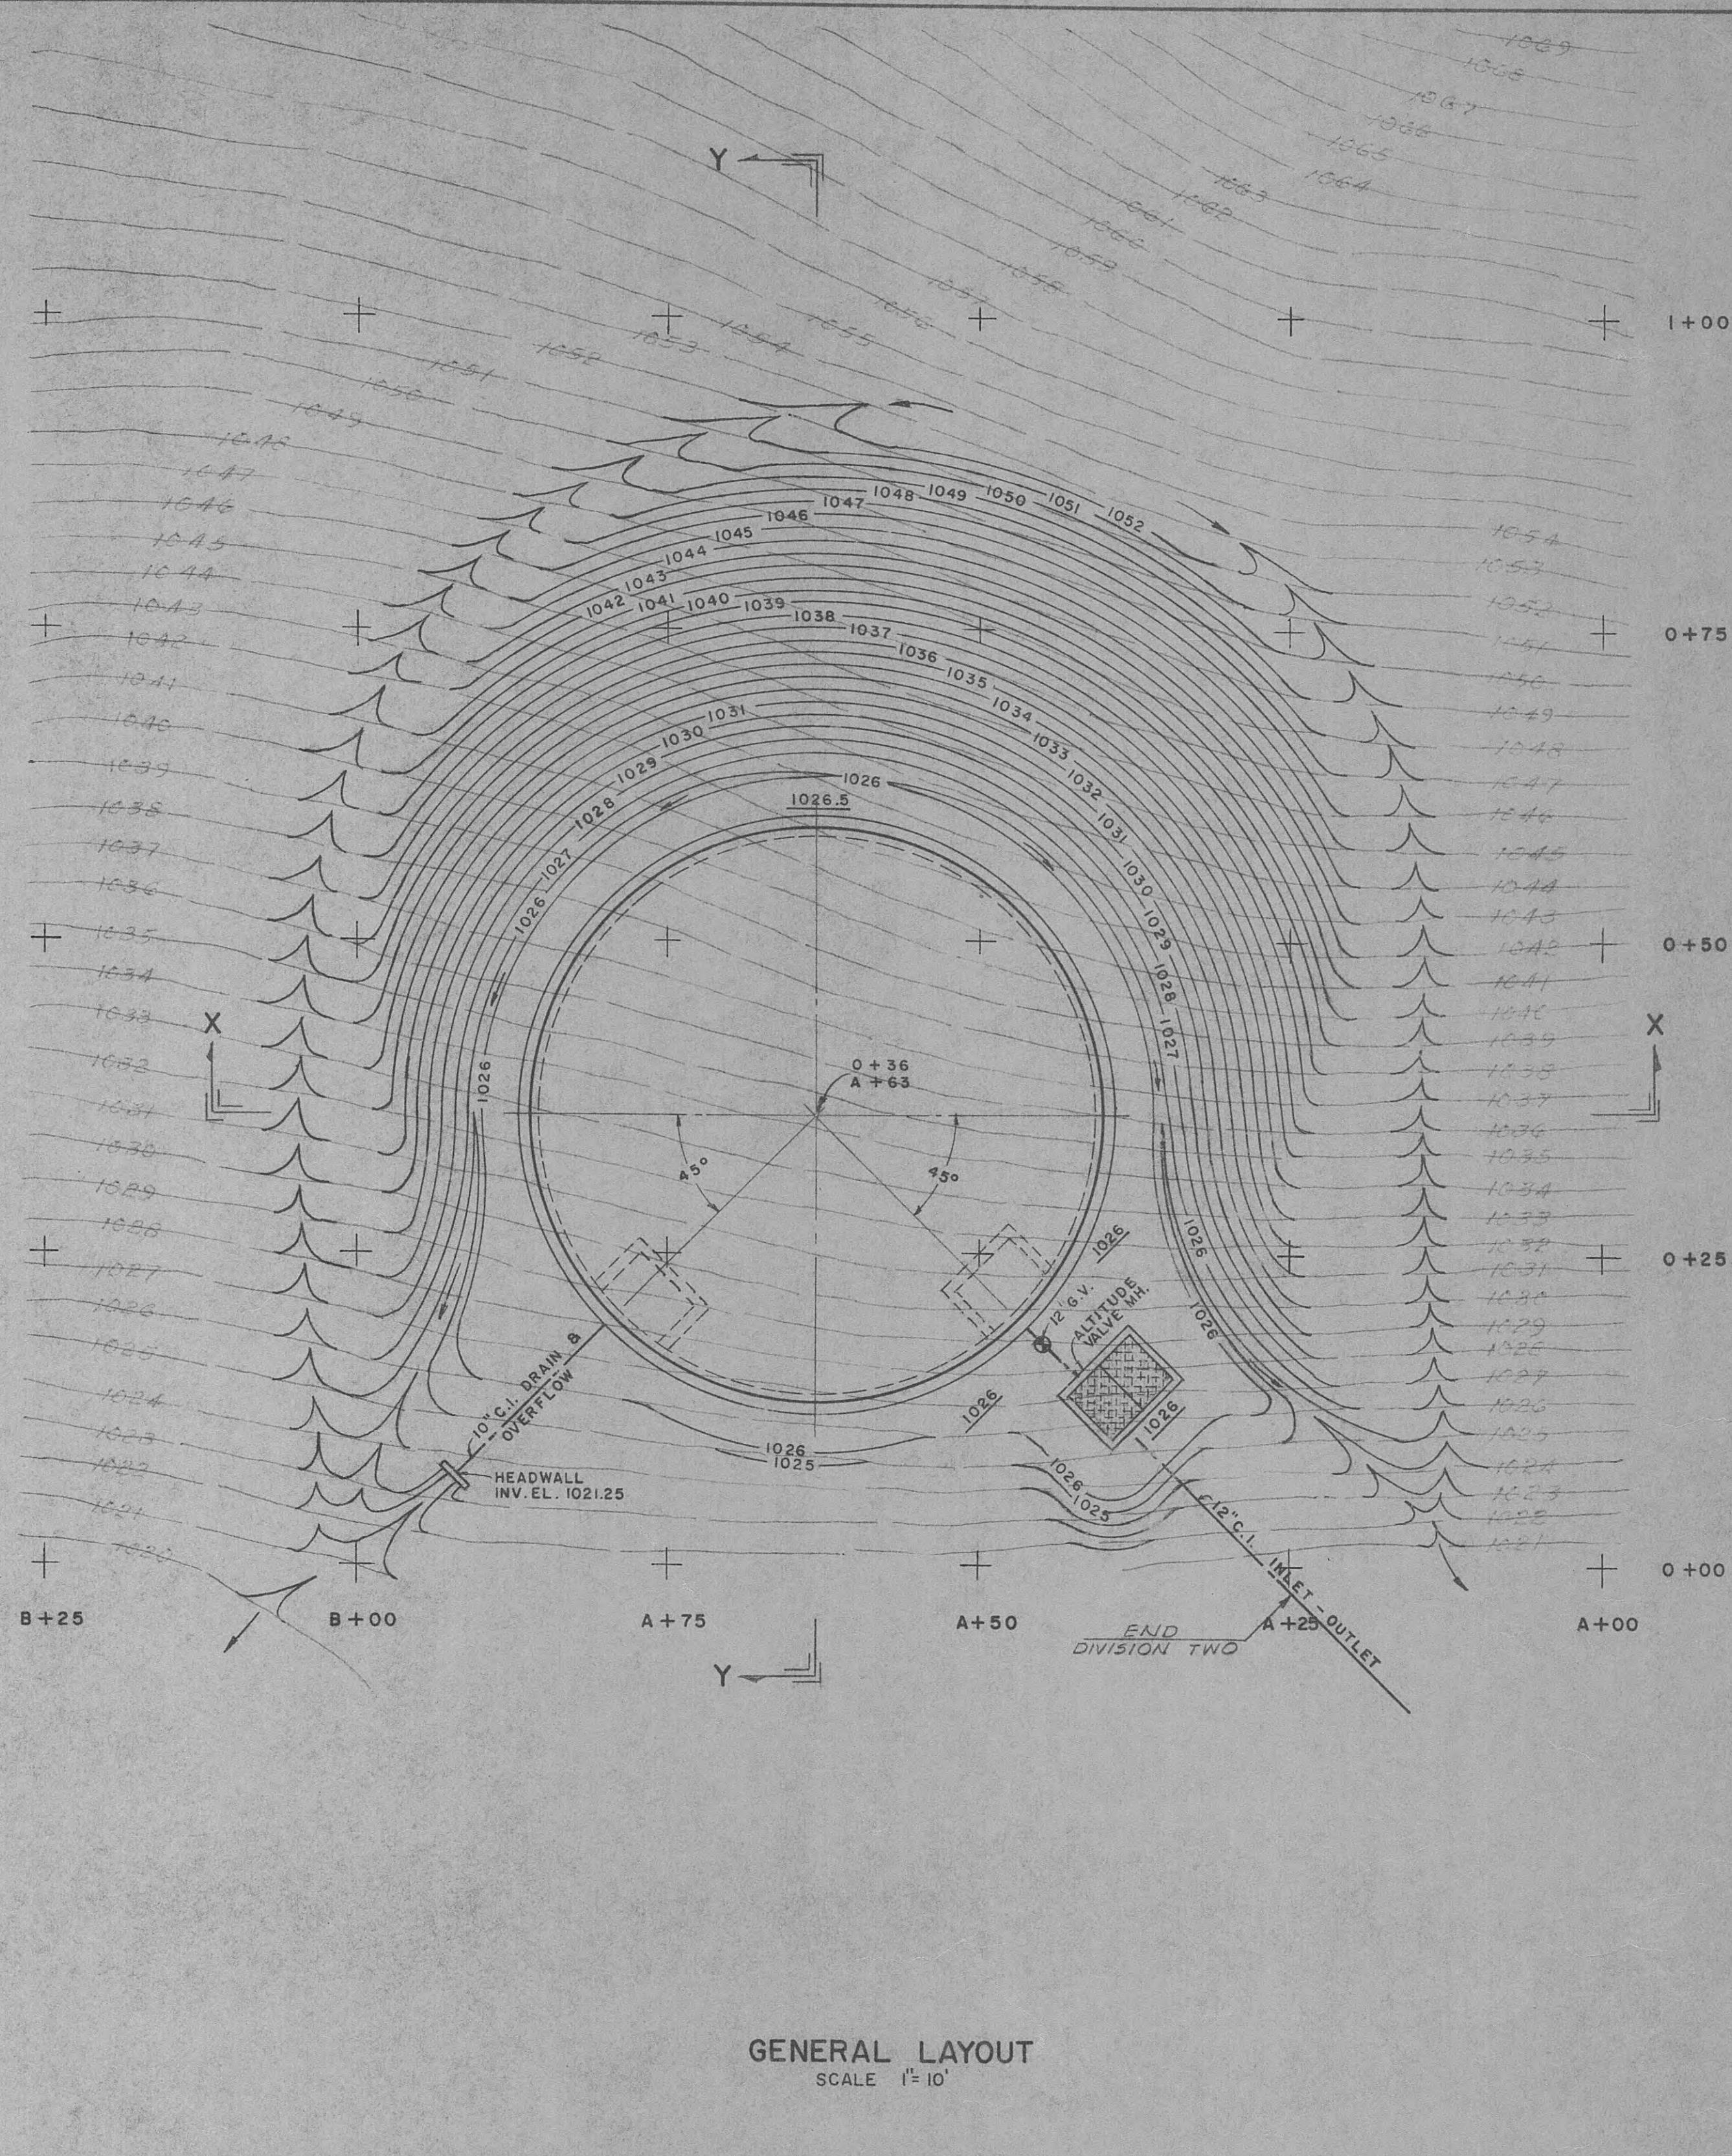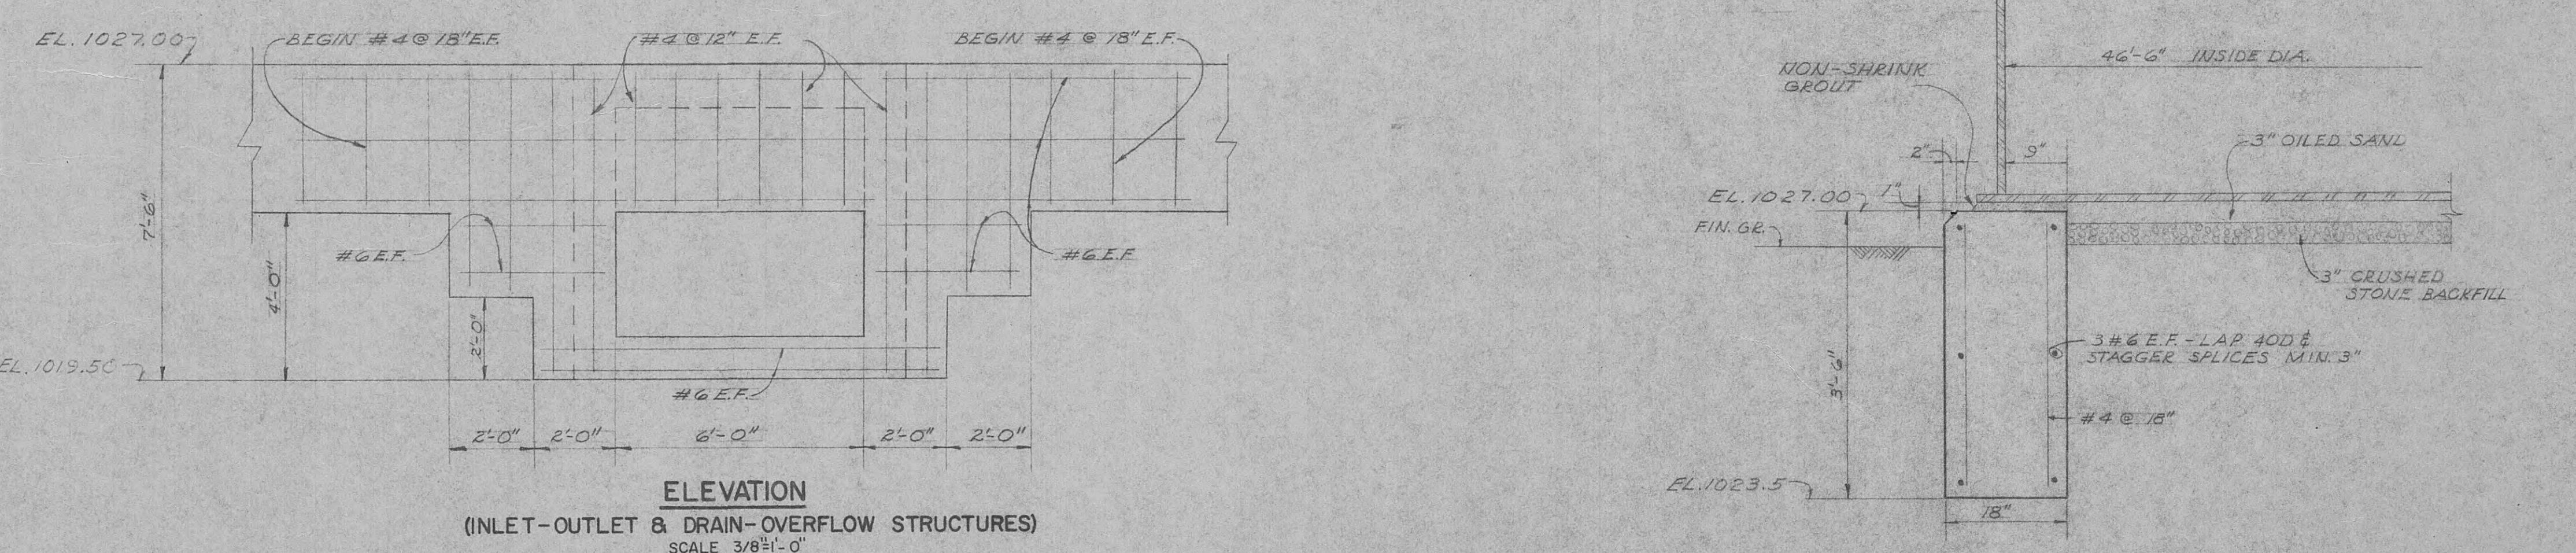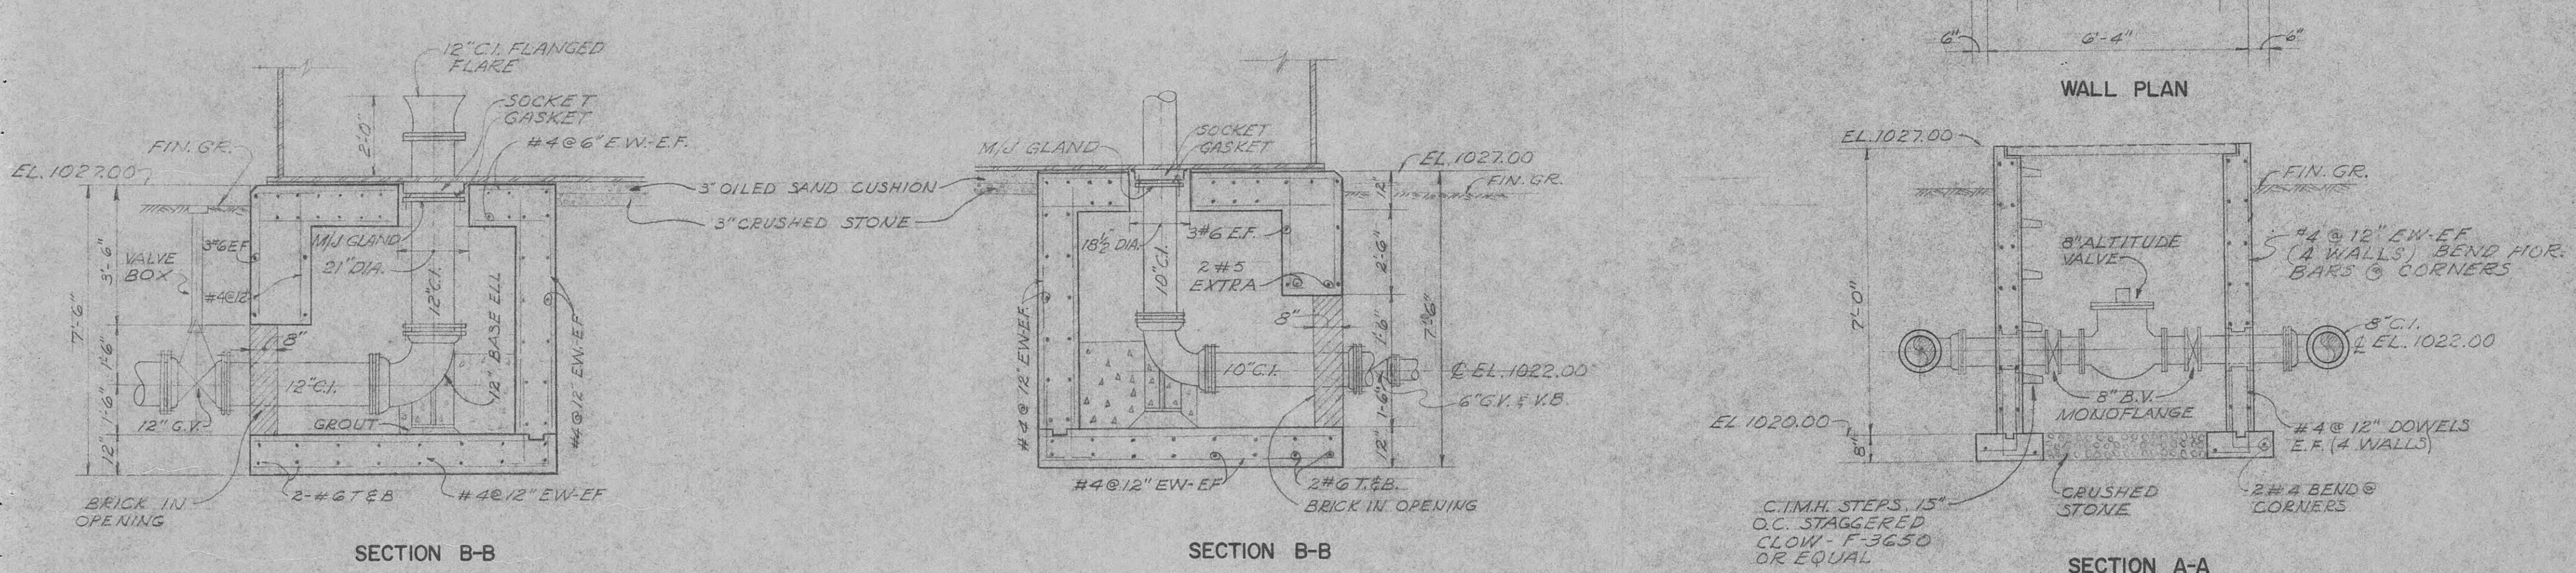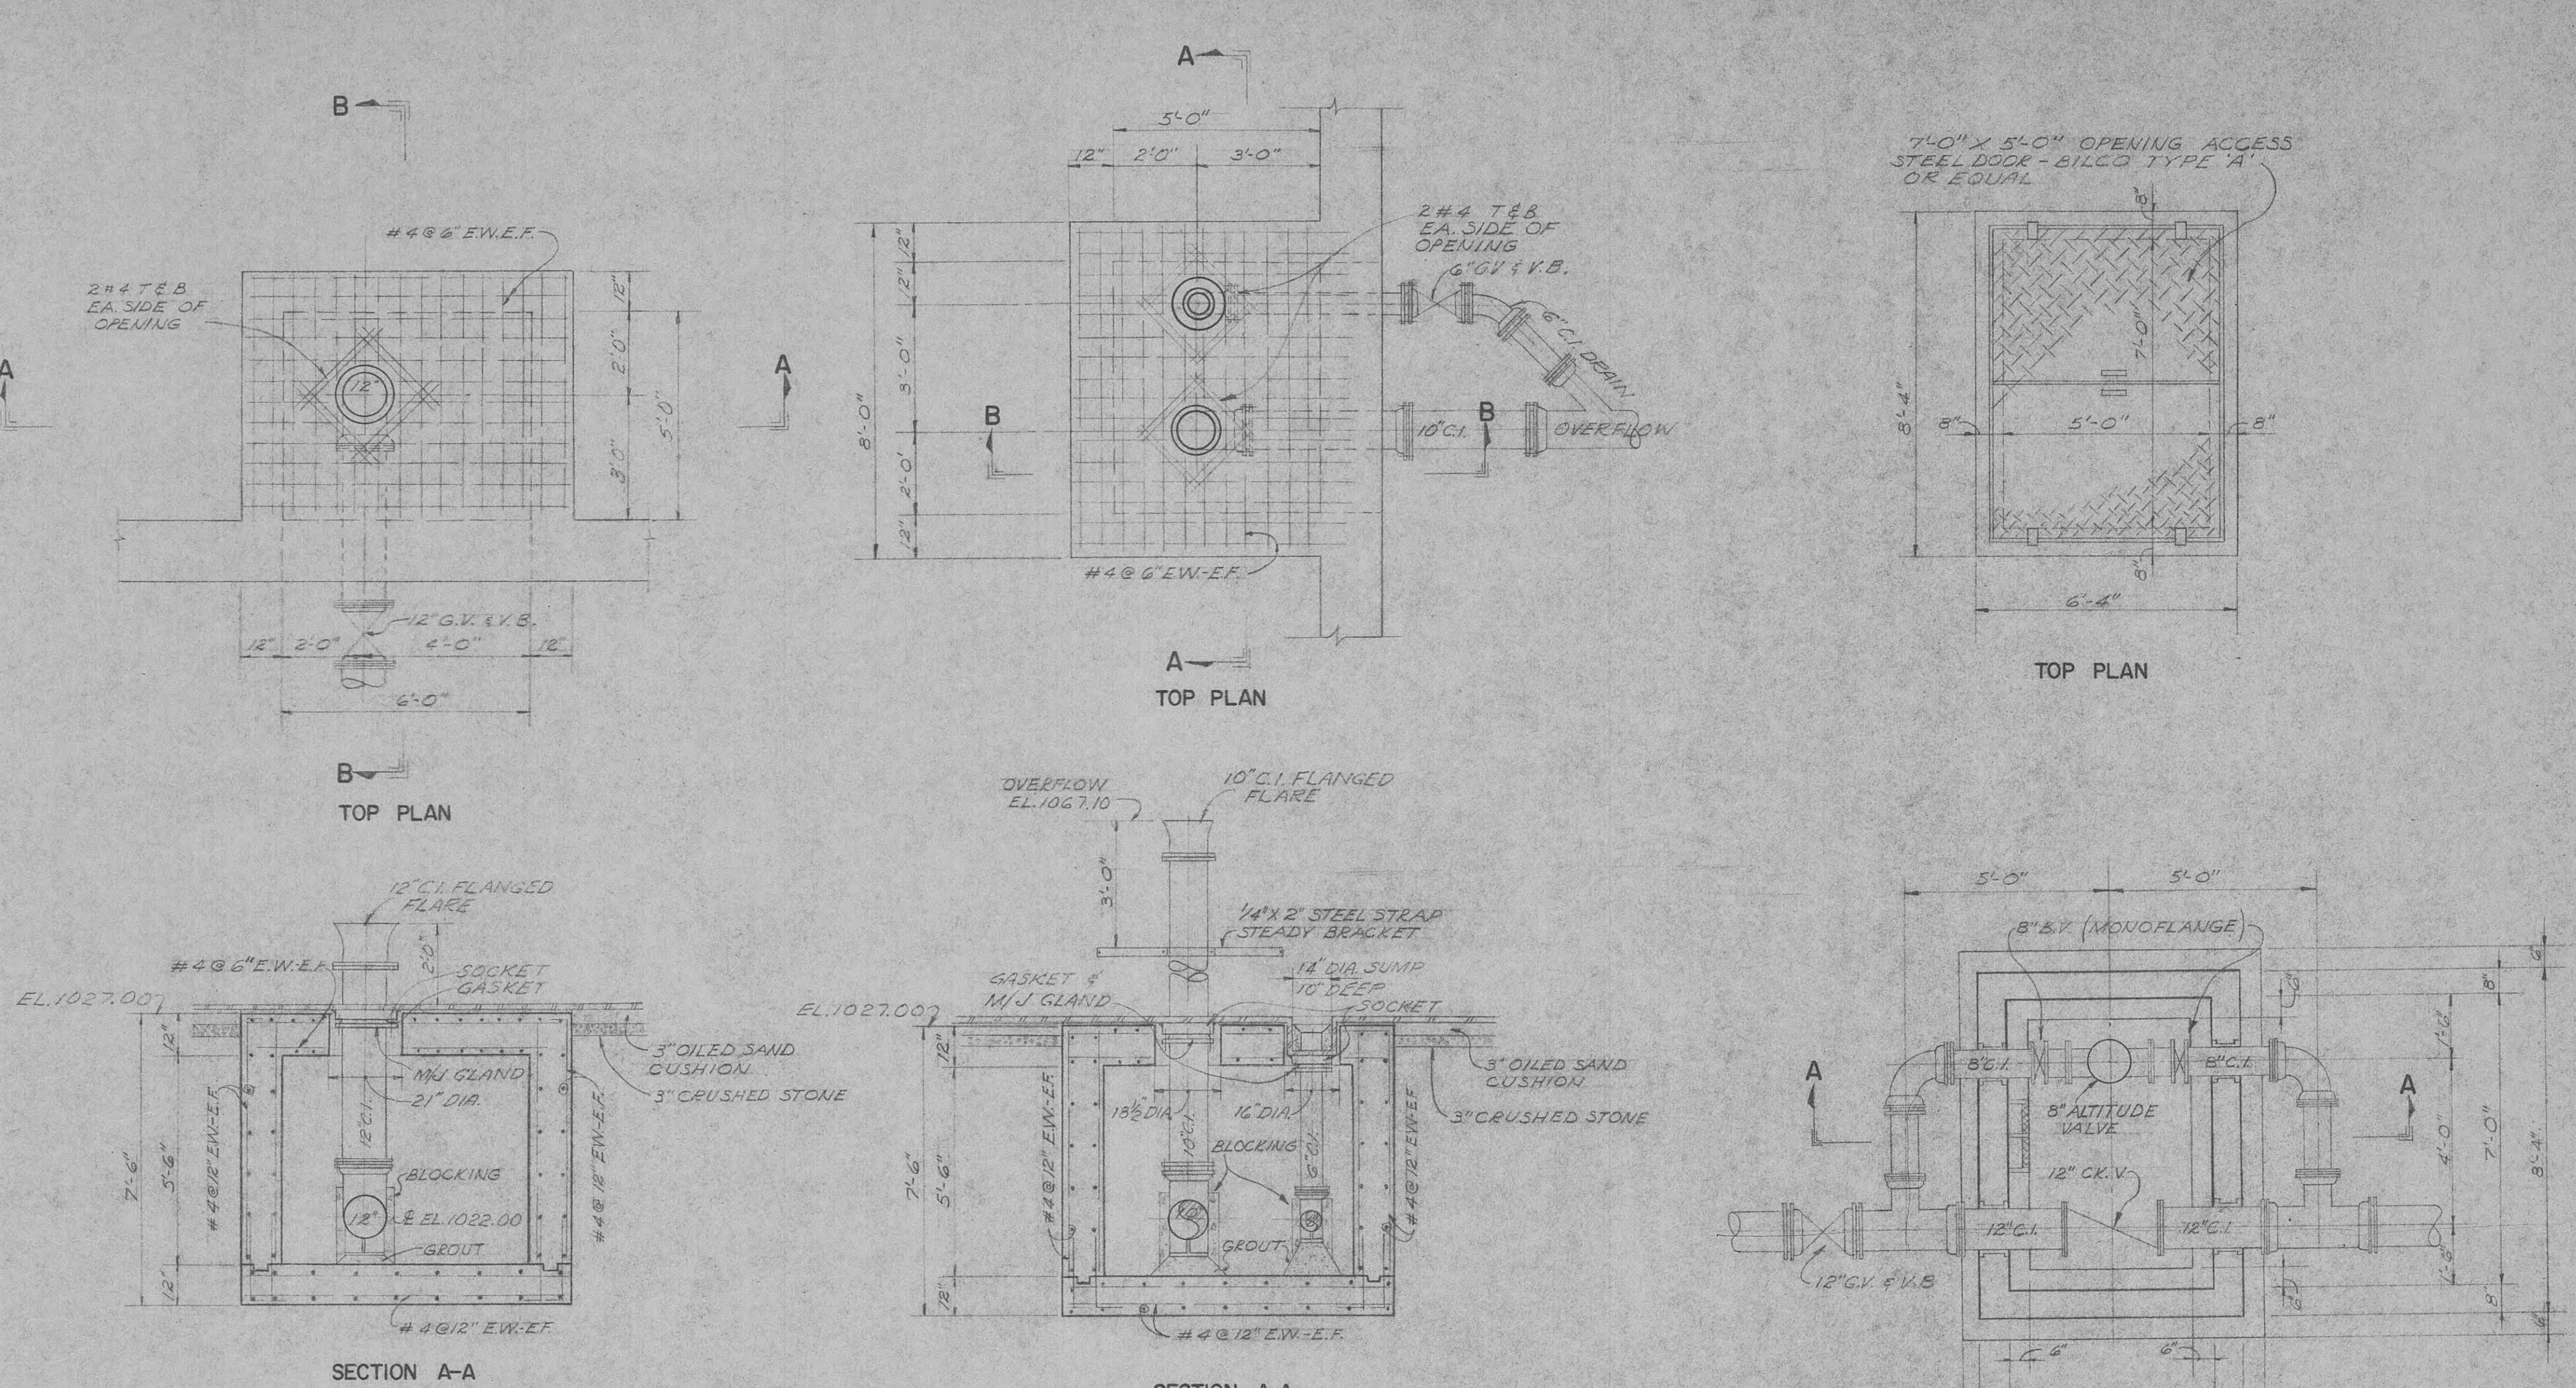




CITY OF HARRIMAN, TENNESSEE
WATER WORKS IMPROVEMENTS
SOUTH HARRIMAN
500,000 GALLON
STORAGE RESERVOIR




SCALE AS SHOWN
DATE MAY, 1966
WIEDEMAN AND SINGLETON
ENGINEERS
ATLANTA, GEORGIA

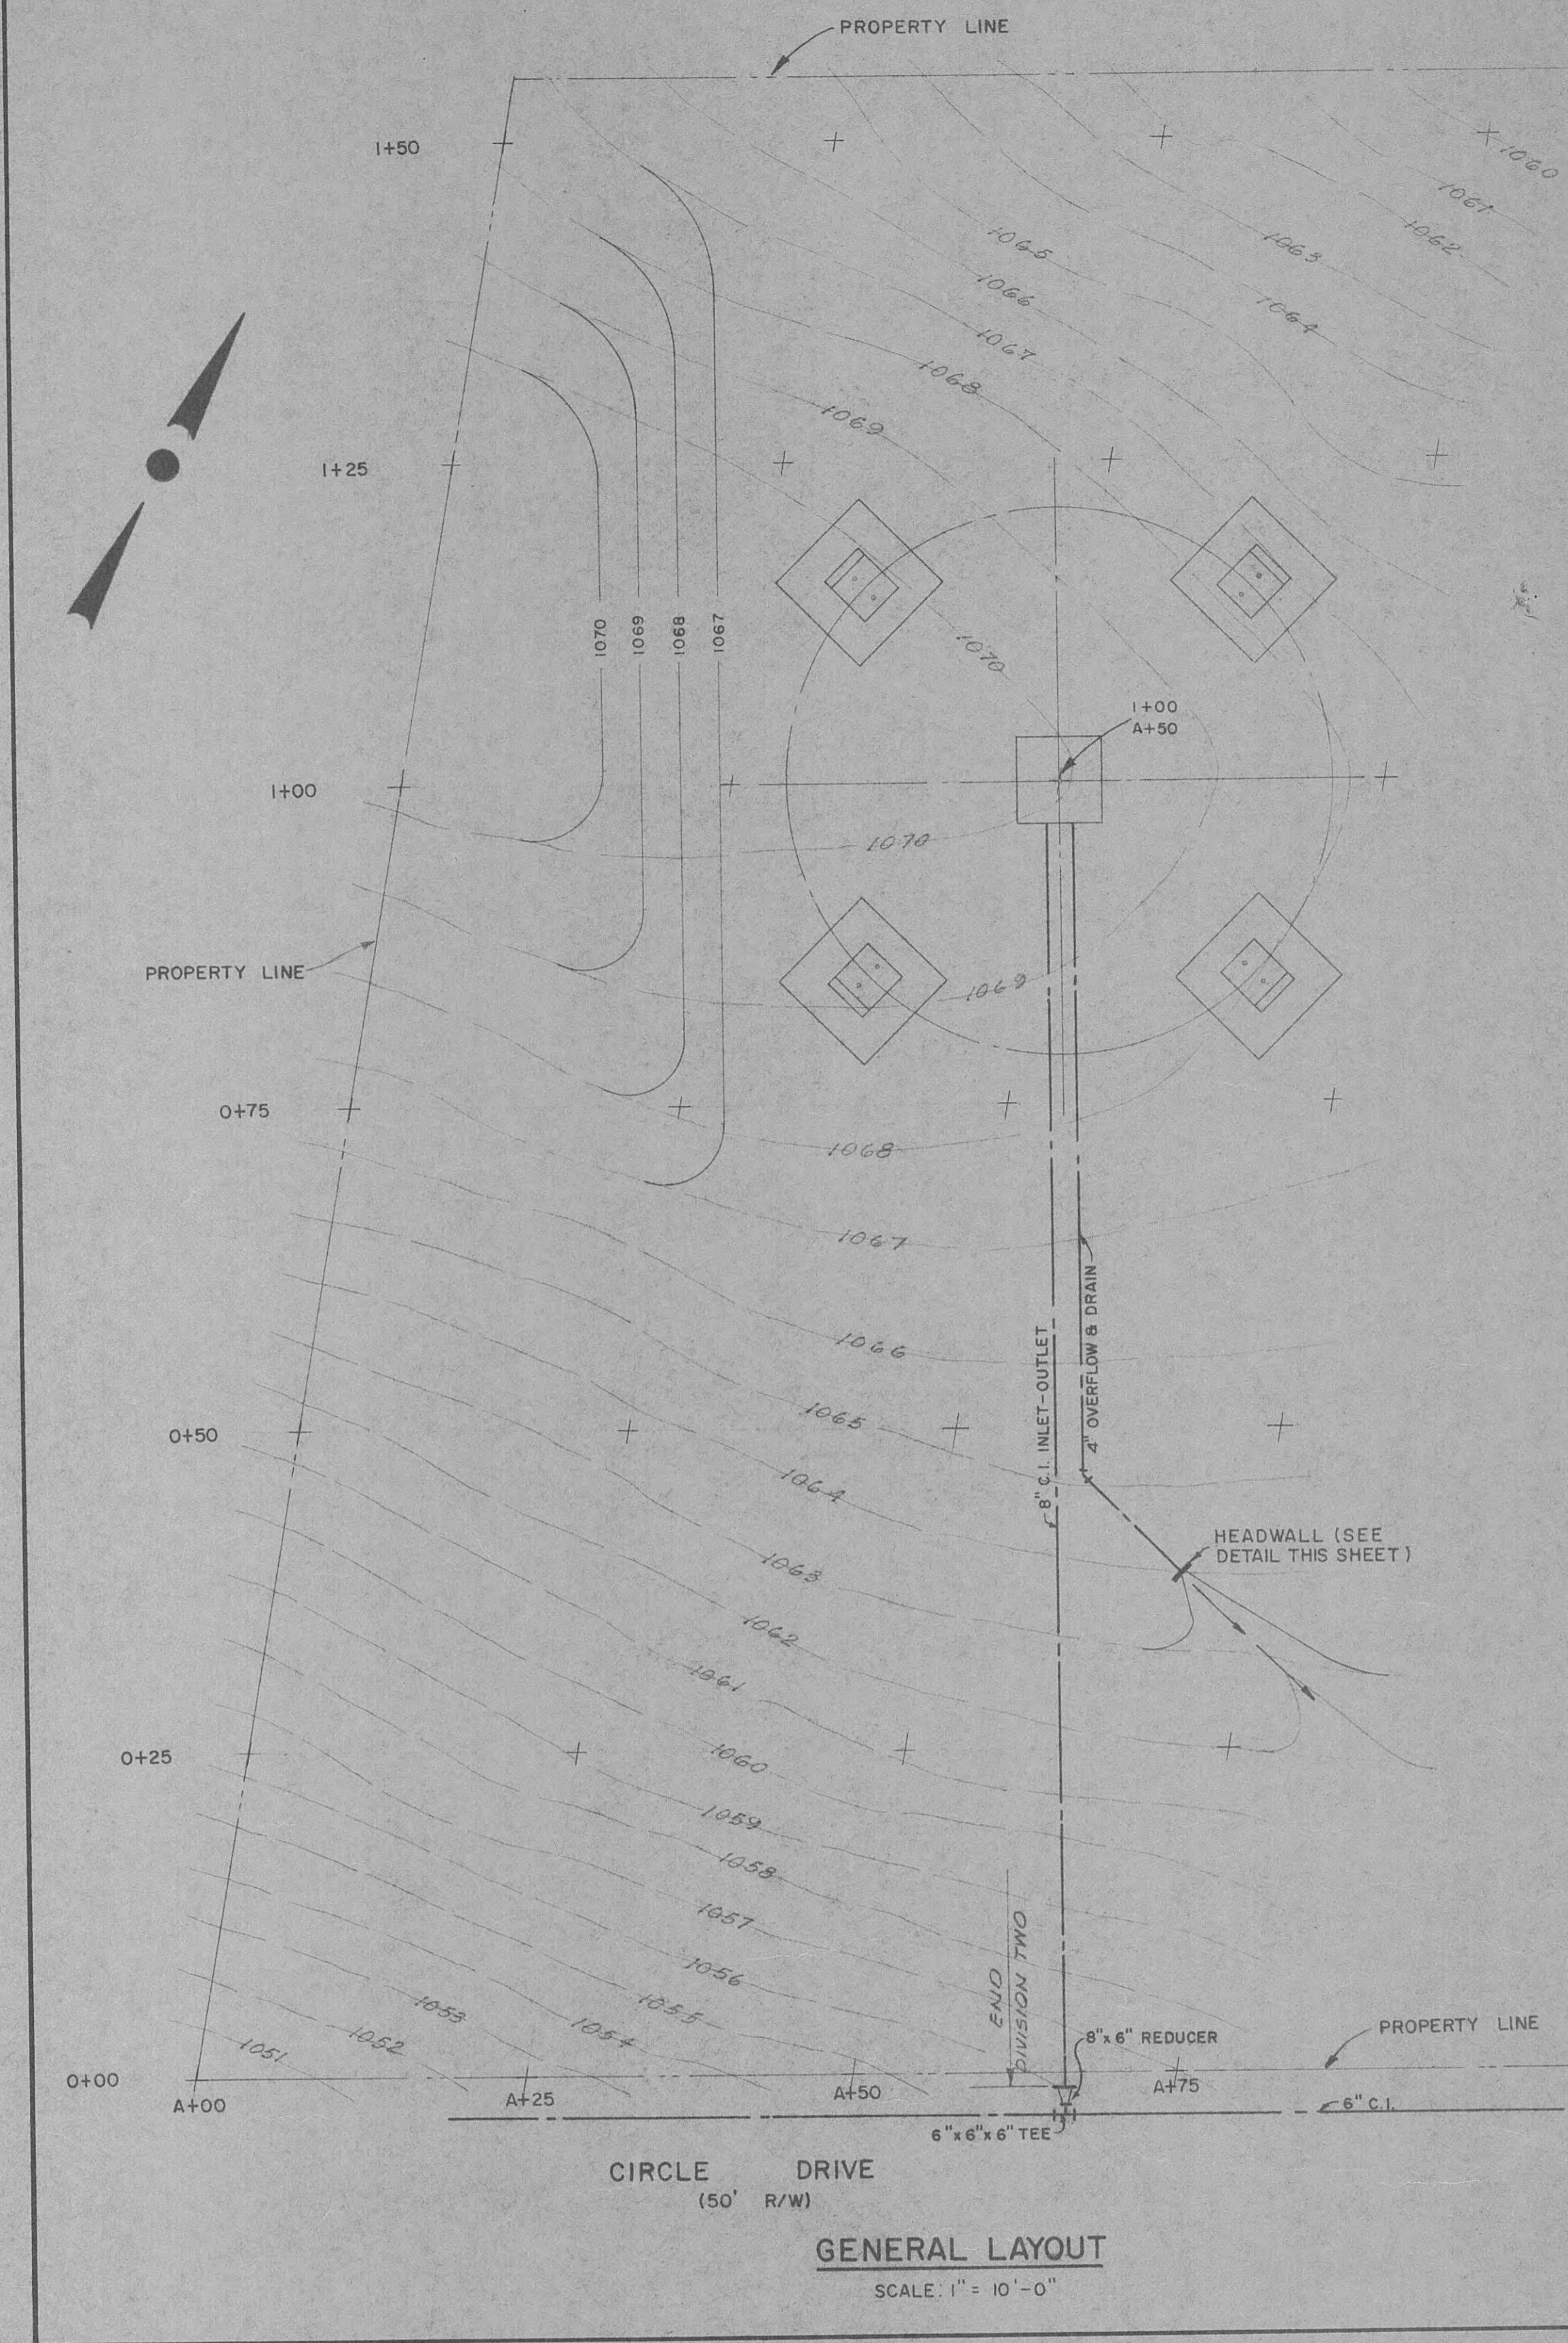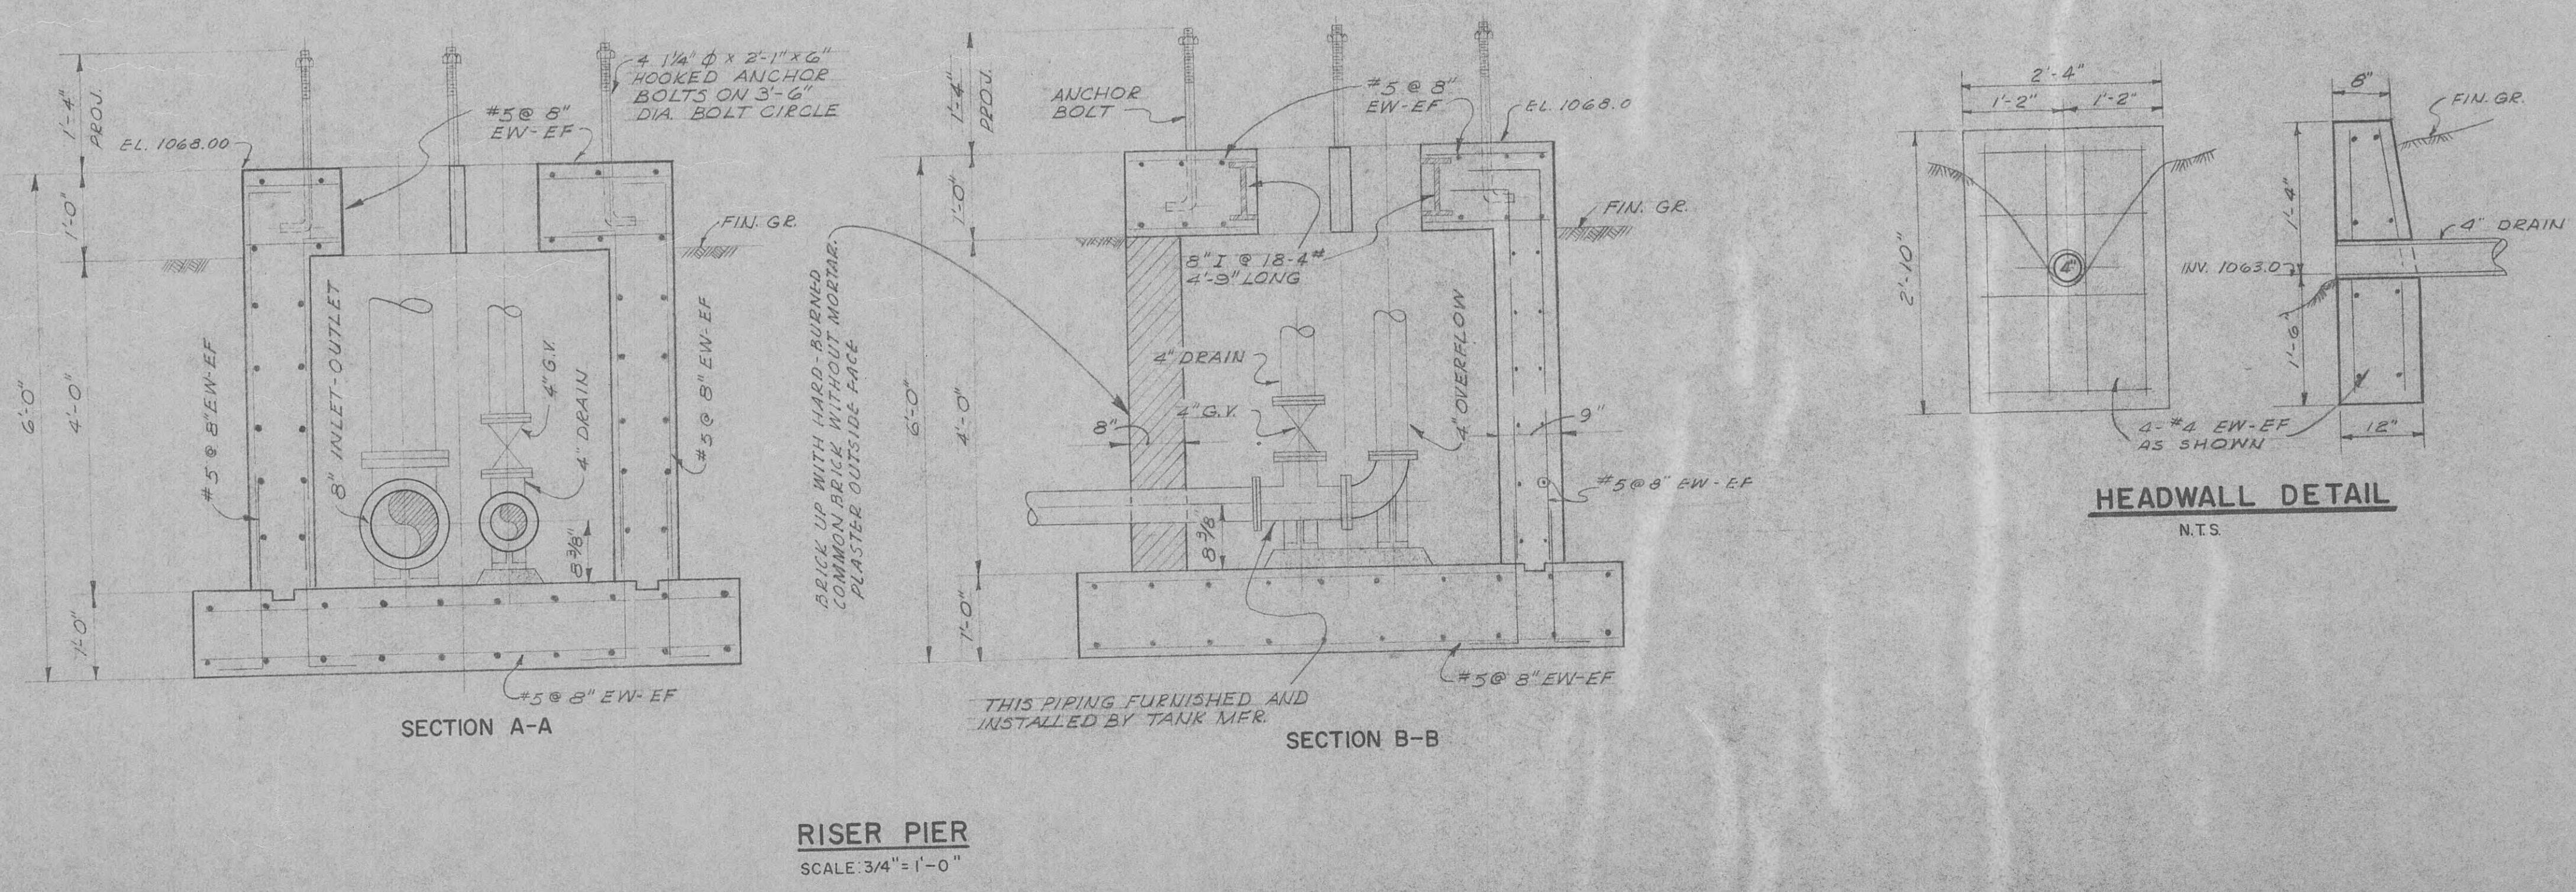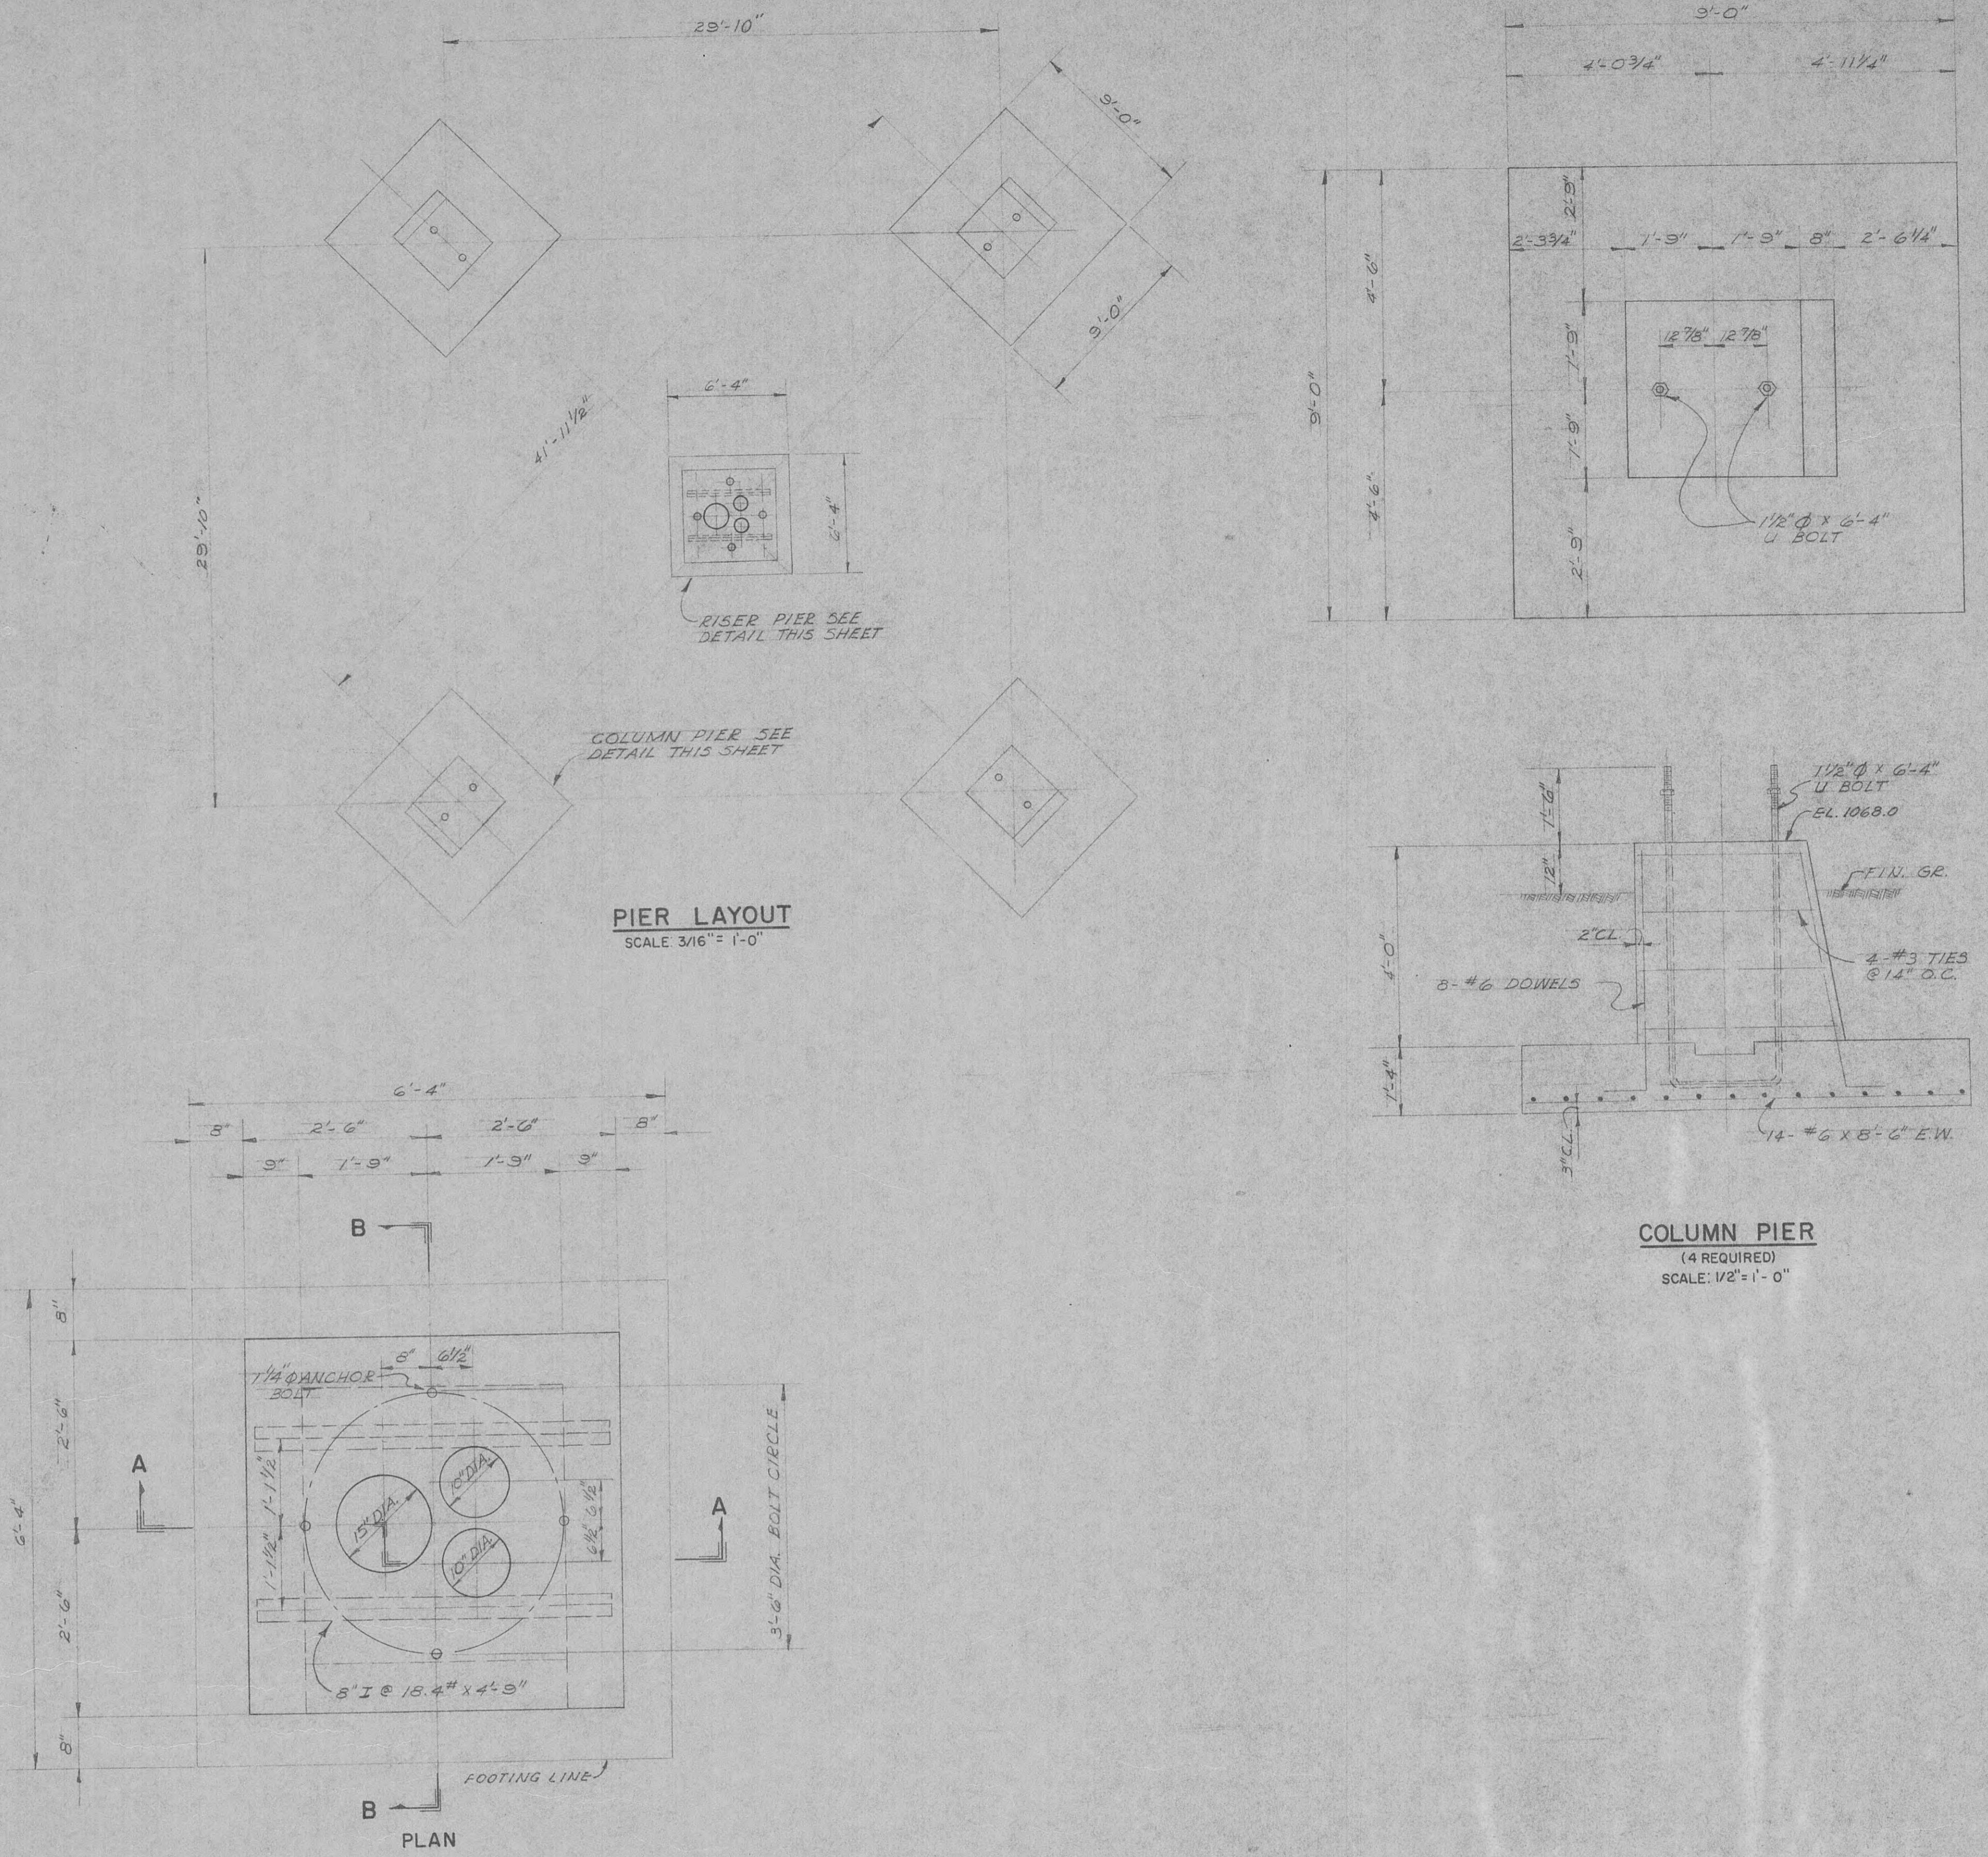

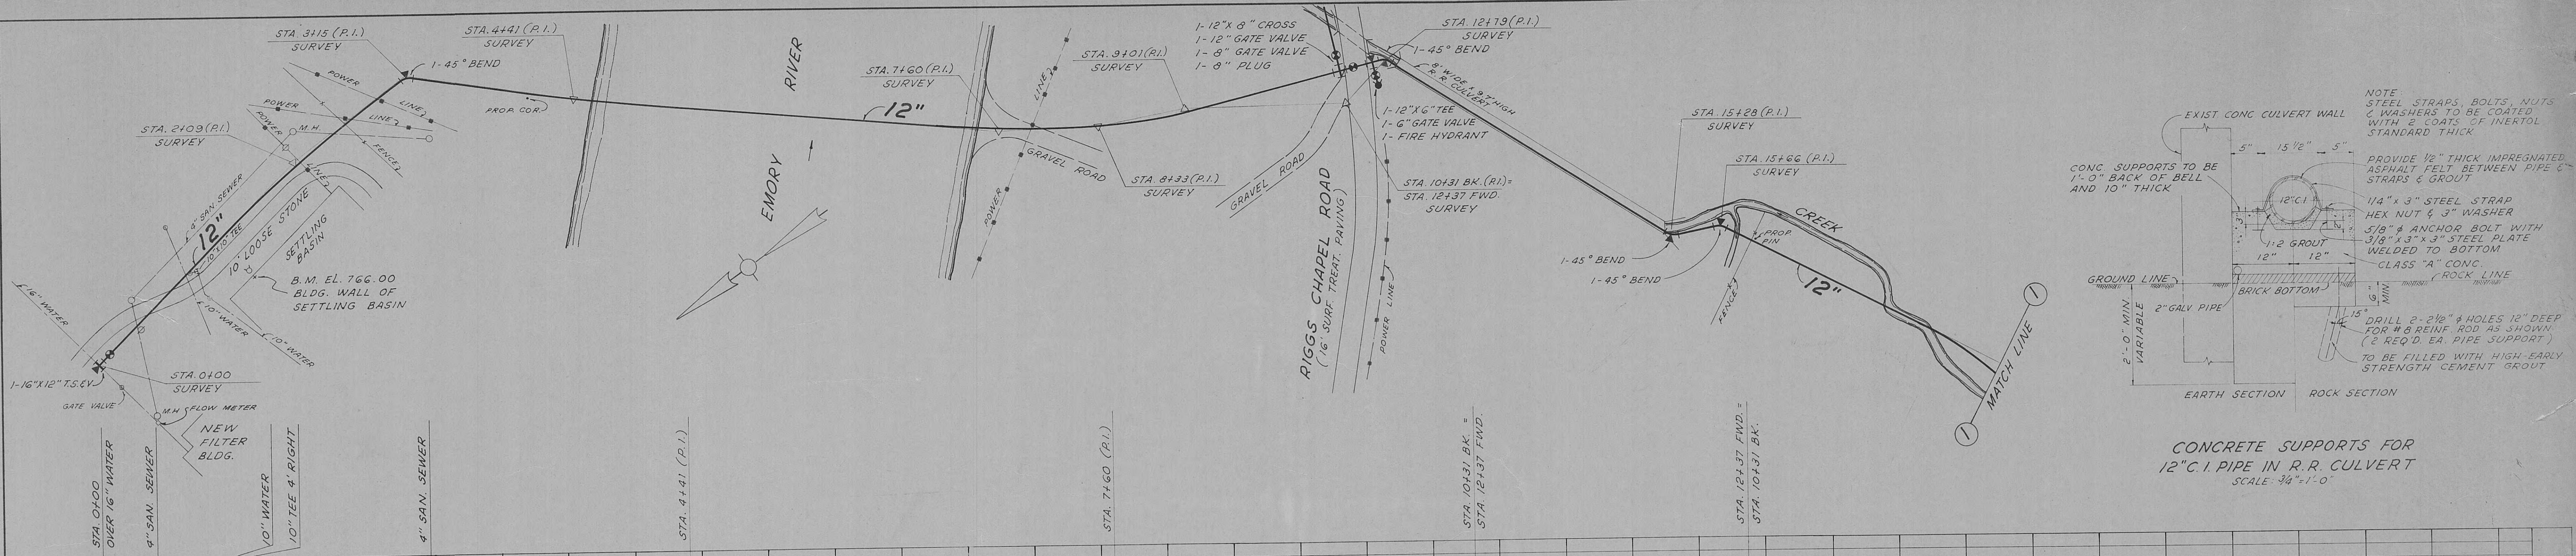

CONCRETE SUPPORTS FOR
12" C.I. PIPE IN R.R. CULVERT
SCALE: $\frac{1}{4}$ " = 1'-0"

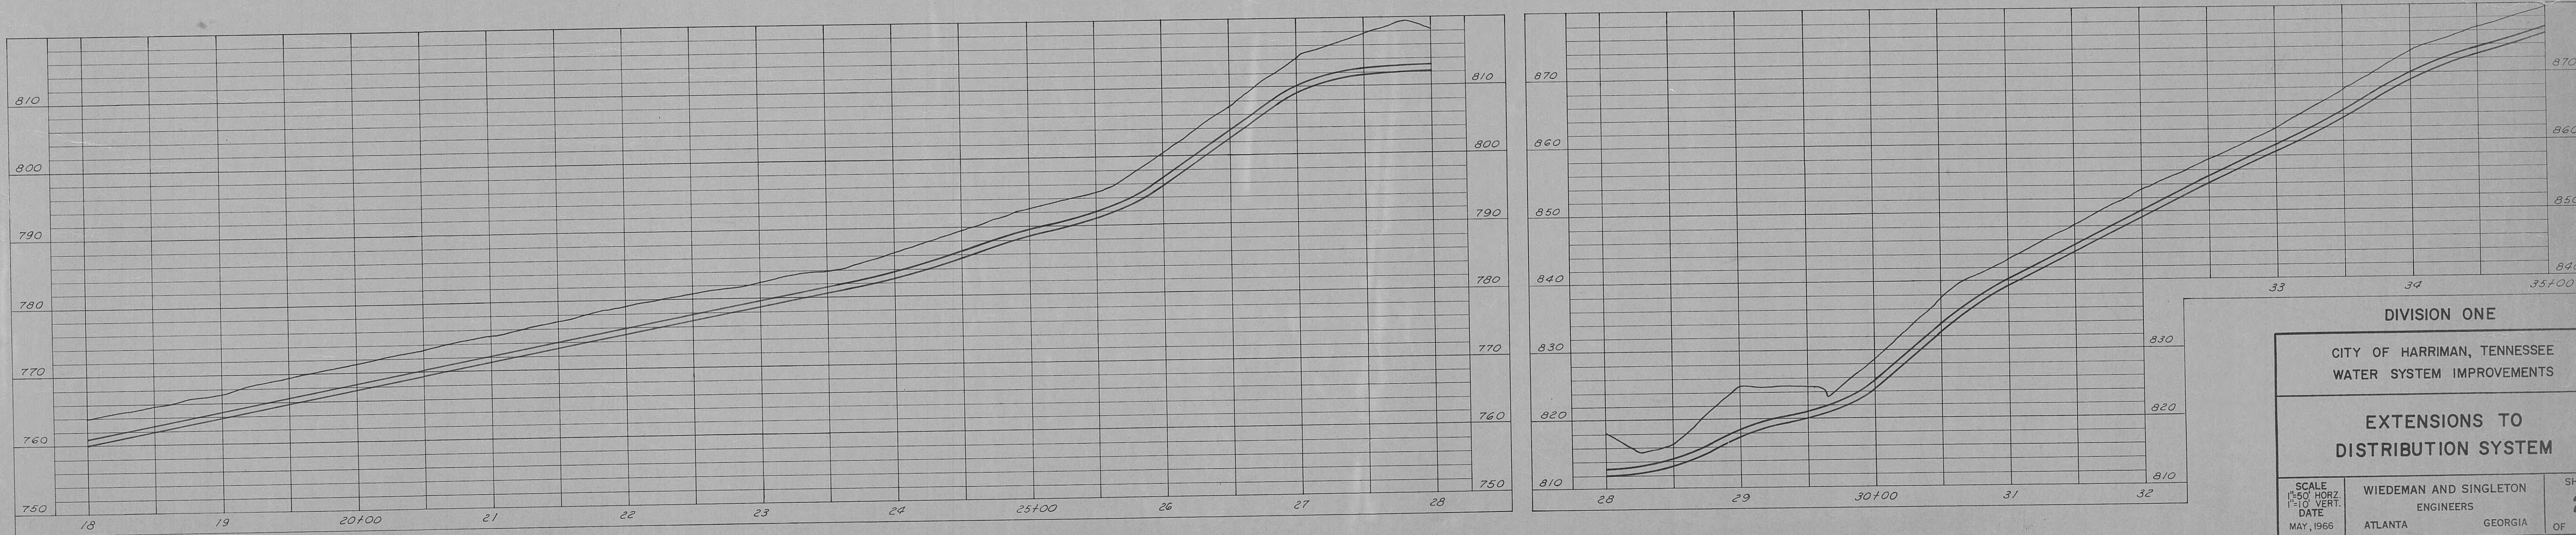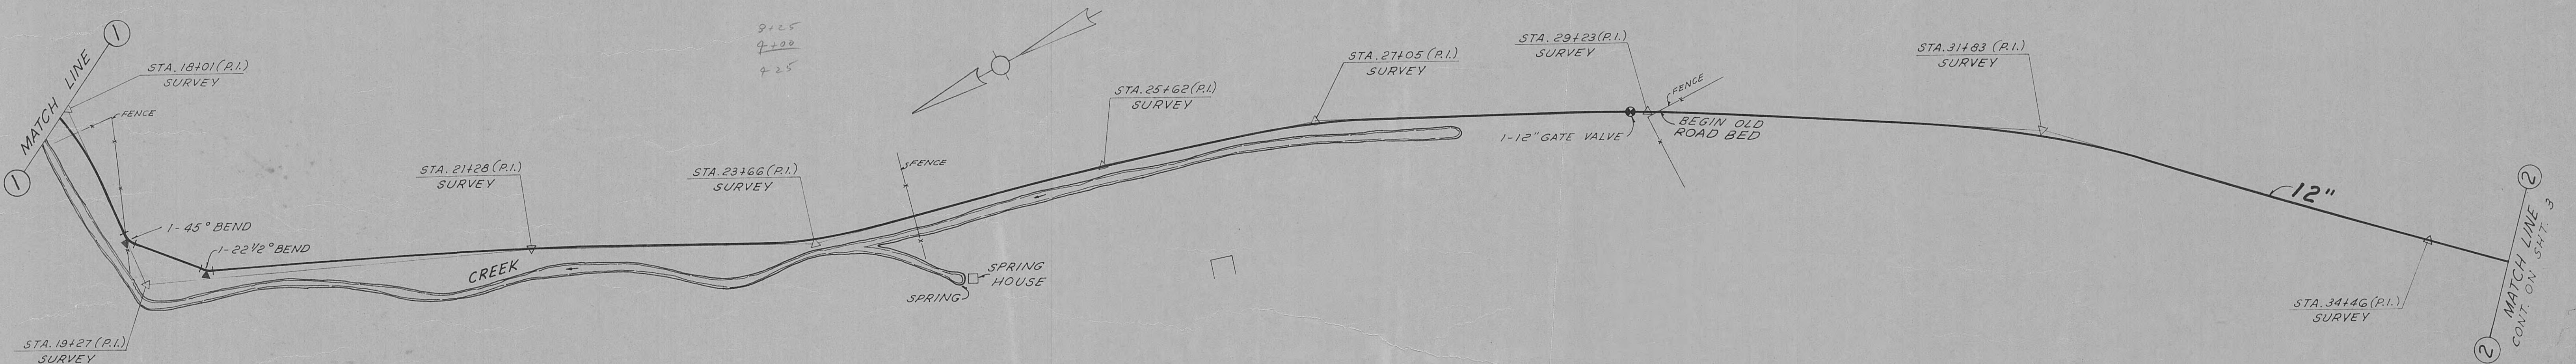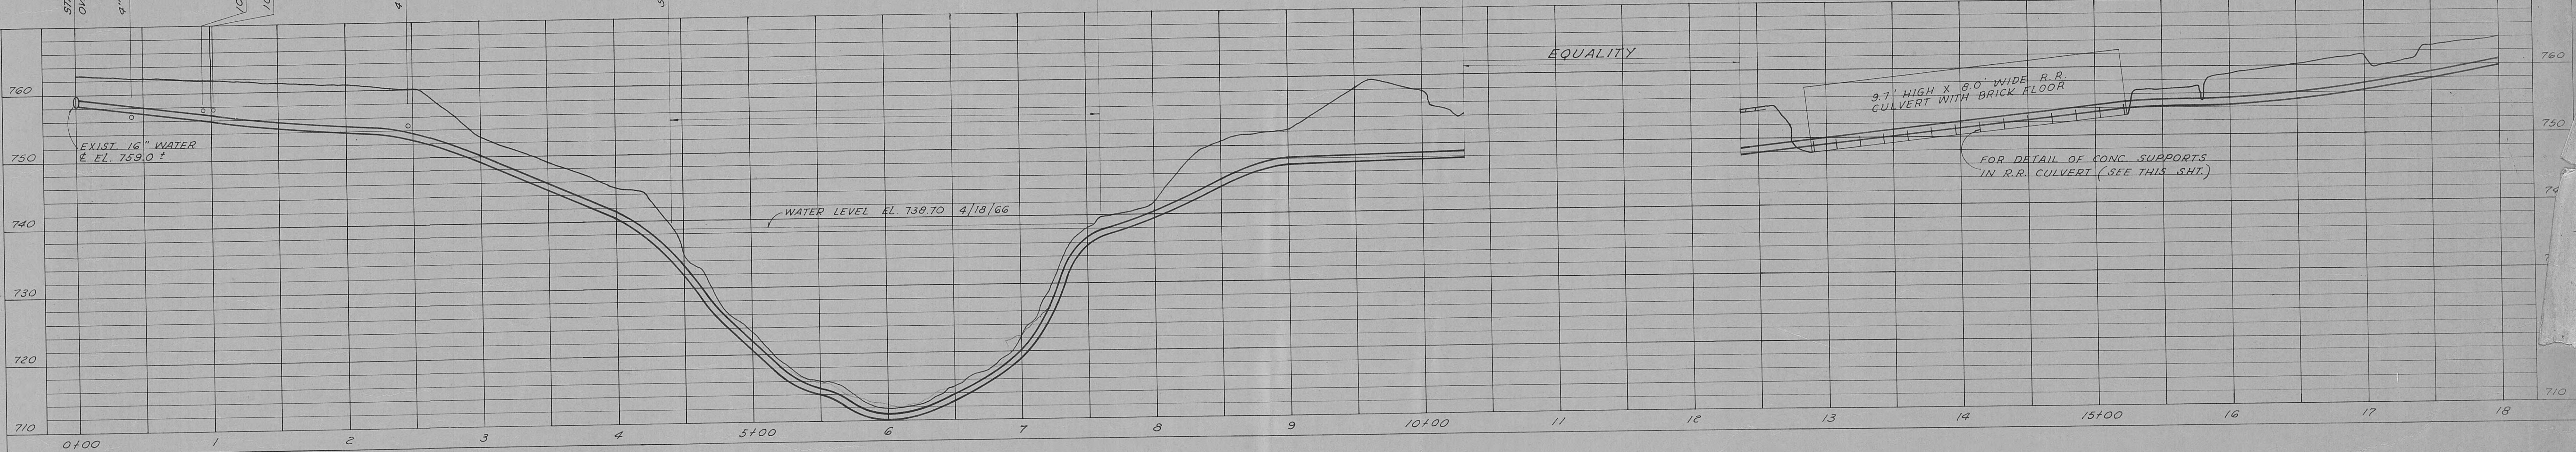

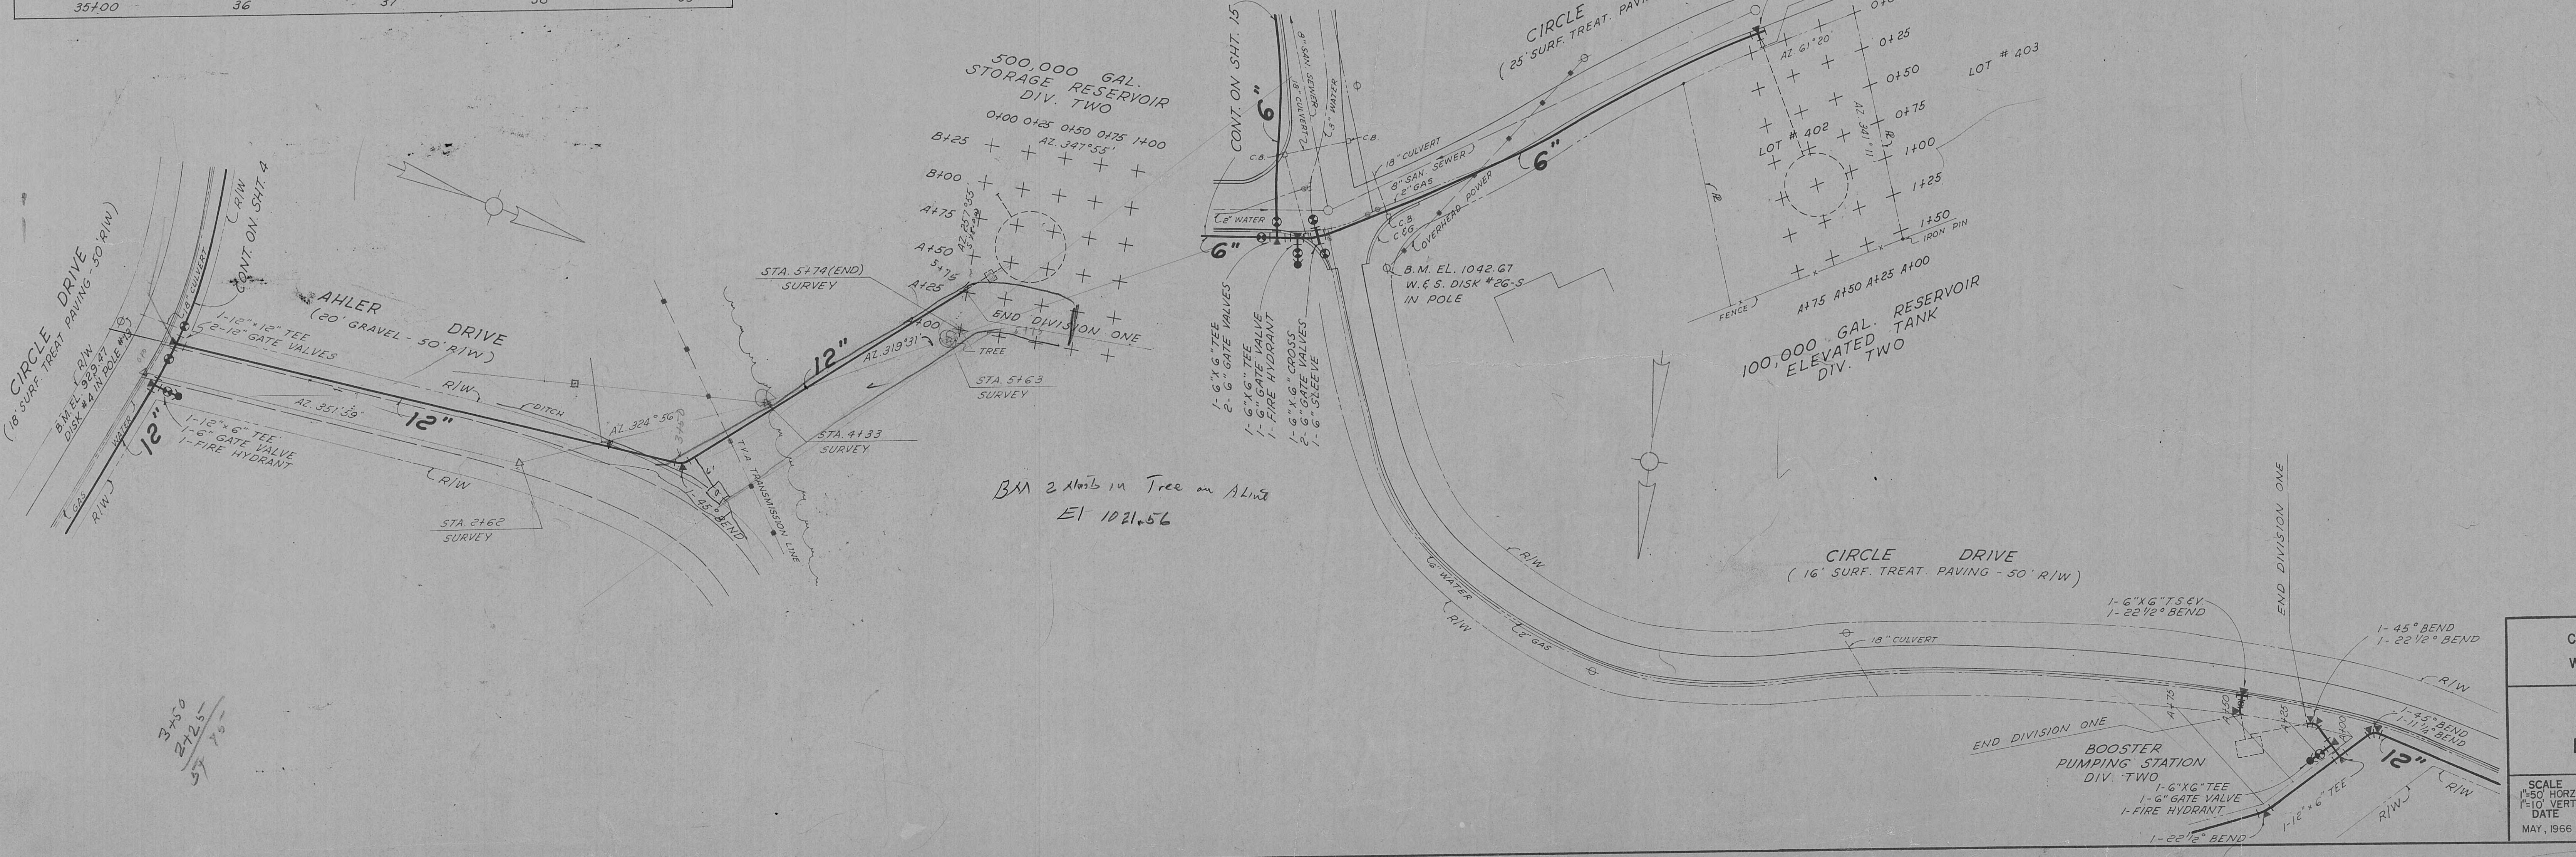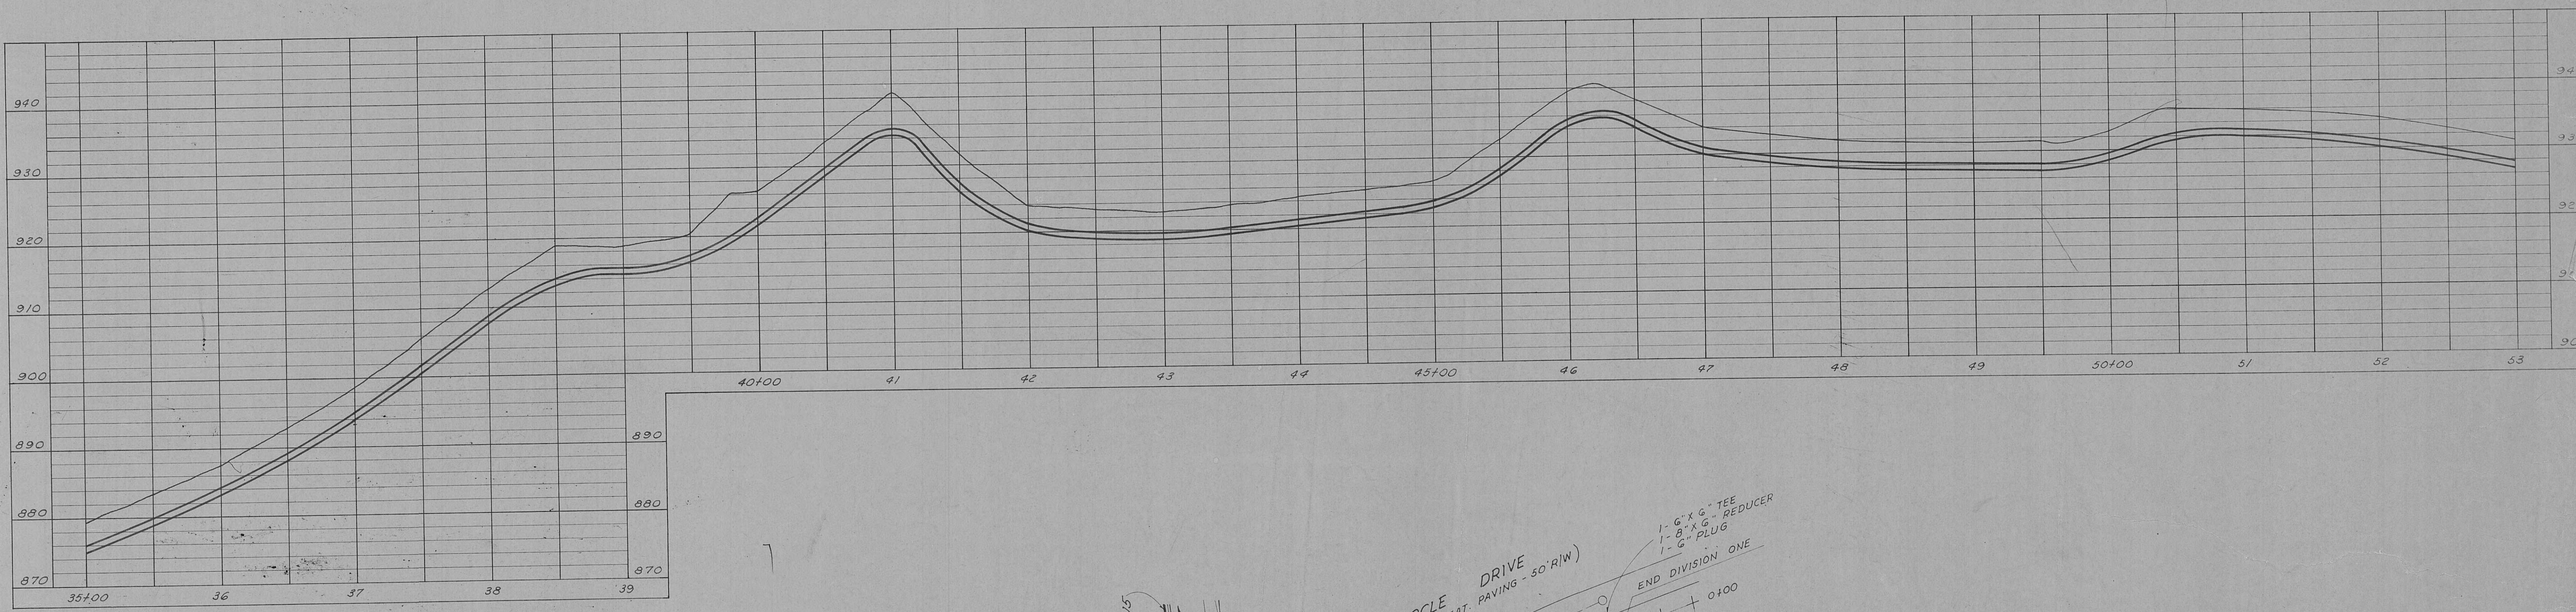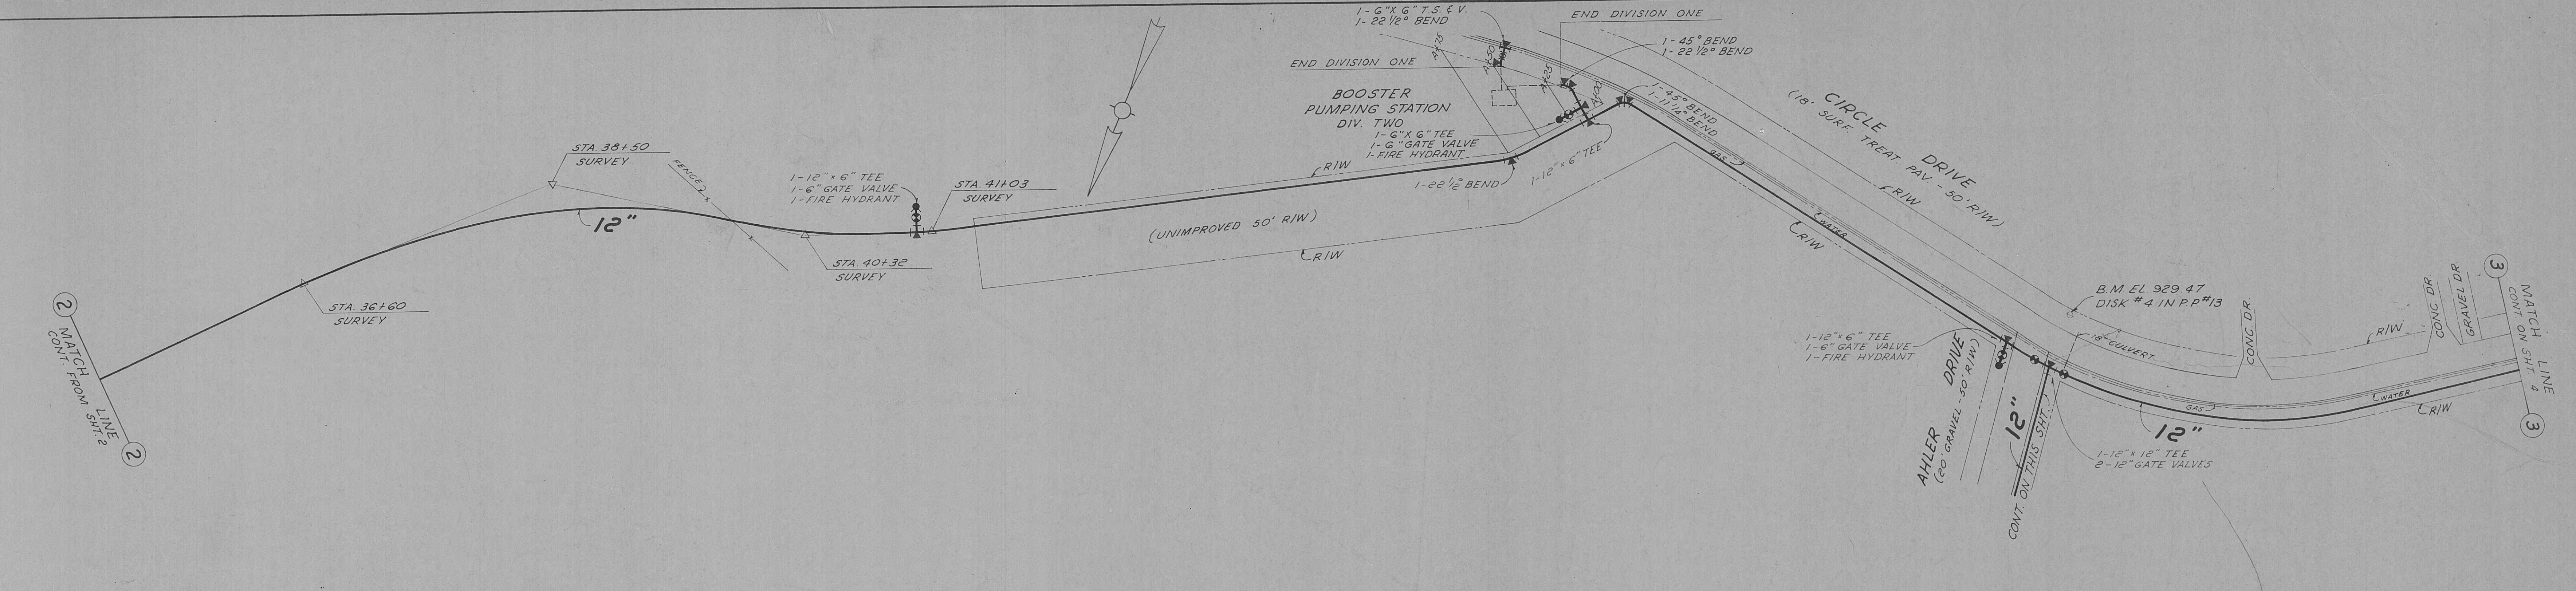


DIVISION ONE

CITY OF HARRIMAN, TENNESSEE
WATER SYSTEM IMPROVEMENTS

EXTENSIONS TO
DISTRIBUTION SYSTEM


SCALE
1" = 100' HORIZ.
1" = 10' VERT.
DATE
MAY, 1966

WIEDEMAN AND SINGLETON
ENGINEERS
ATLANTA, GEORGIA

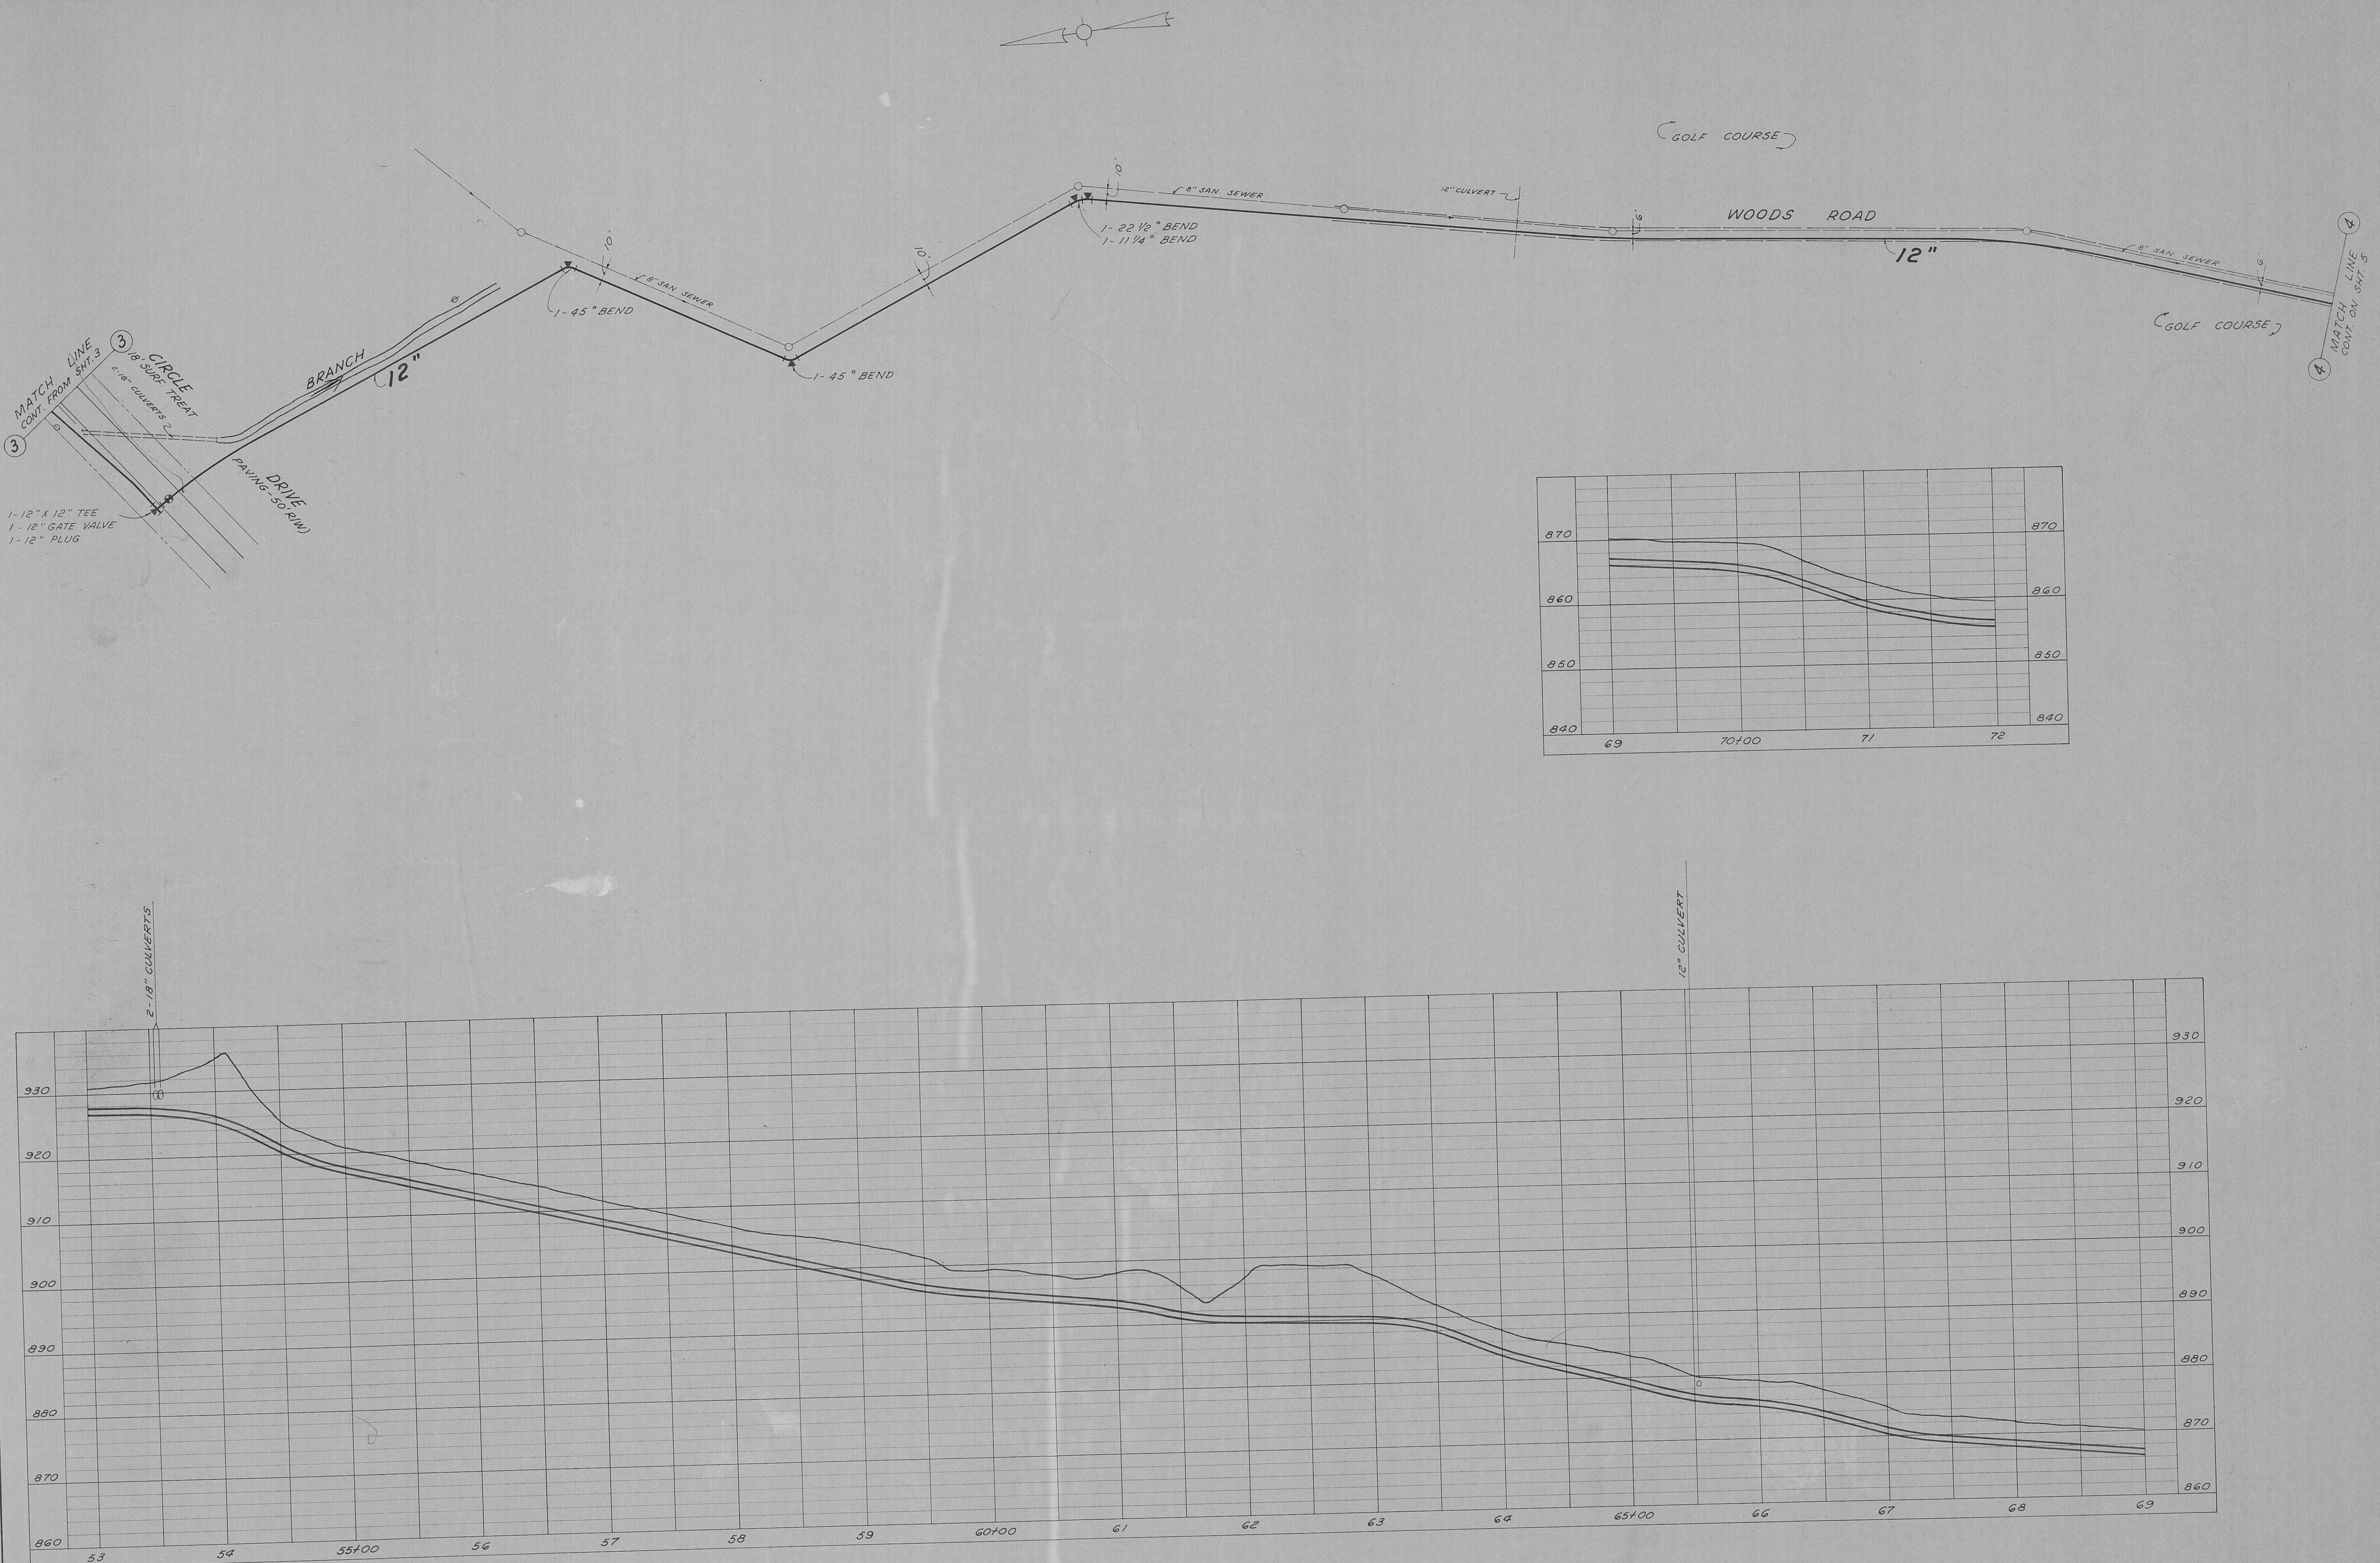


DIVISION ONE

CITY OF HARRIMAN, TENNESSEE
WATER SYSTEM IMPROVEMENTEXTENSIONS TO
DISTRIBUTION SYSTEMSCALE
1/500 HORZ.
1/50 VERT.
DATE
MAY, 1966WIEDEMAN AND SINGLETON
ENGINEERS
ATLANTA GEORGIA

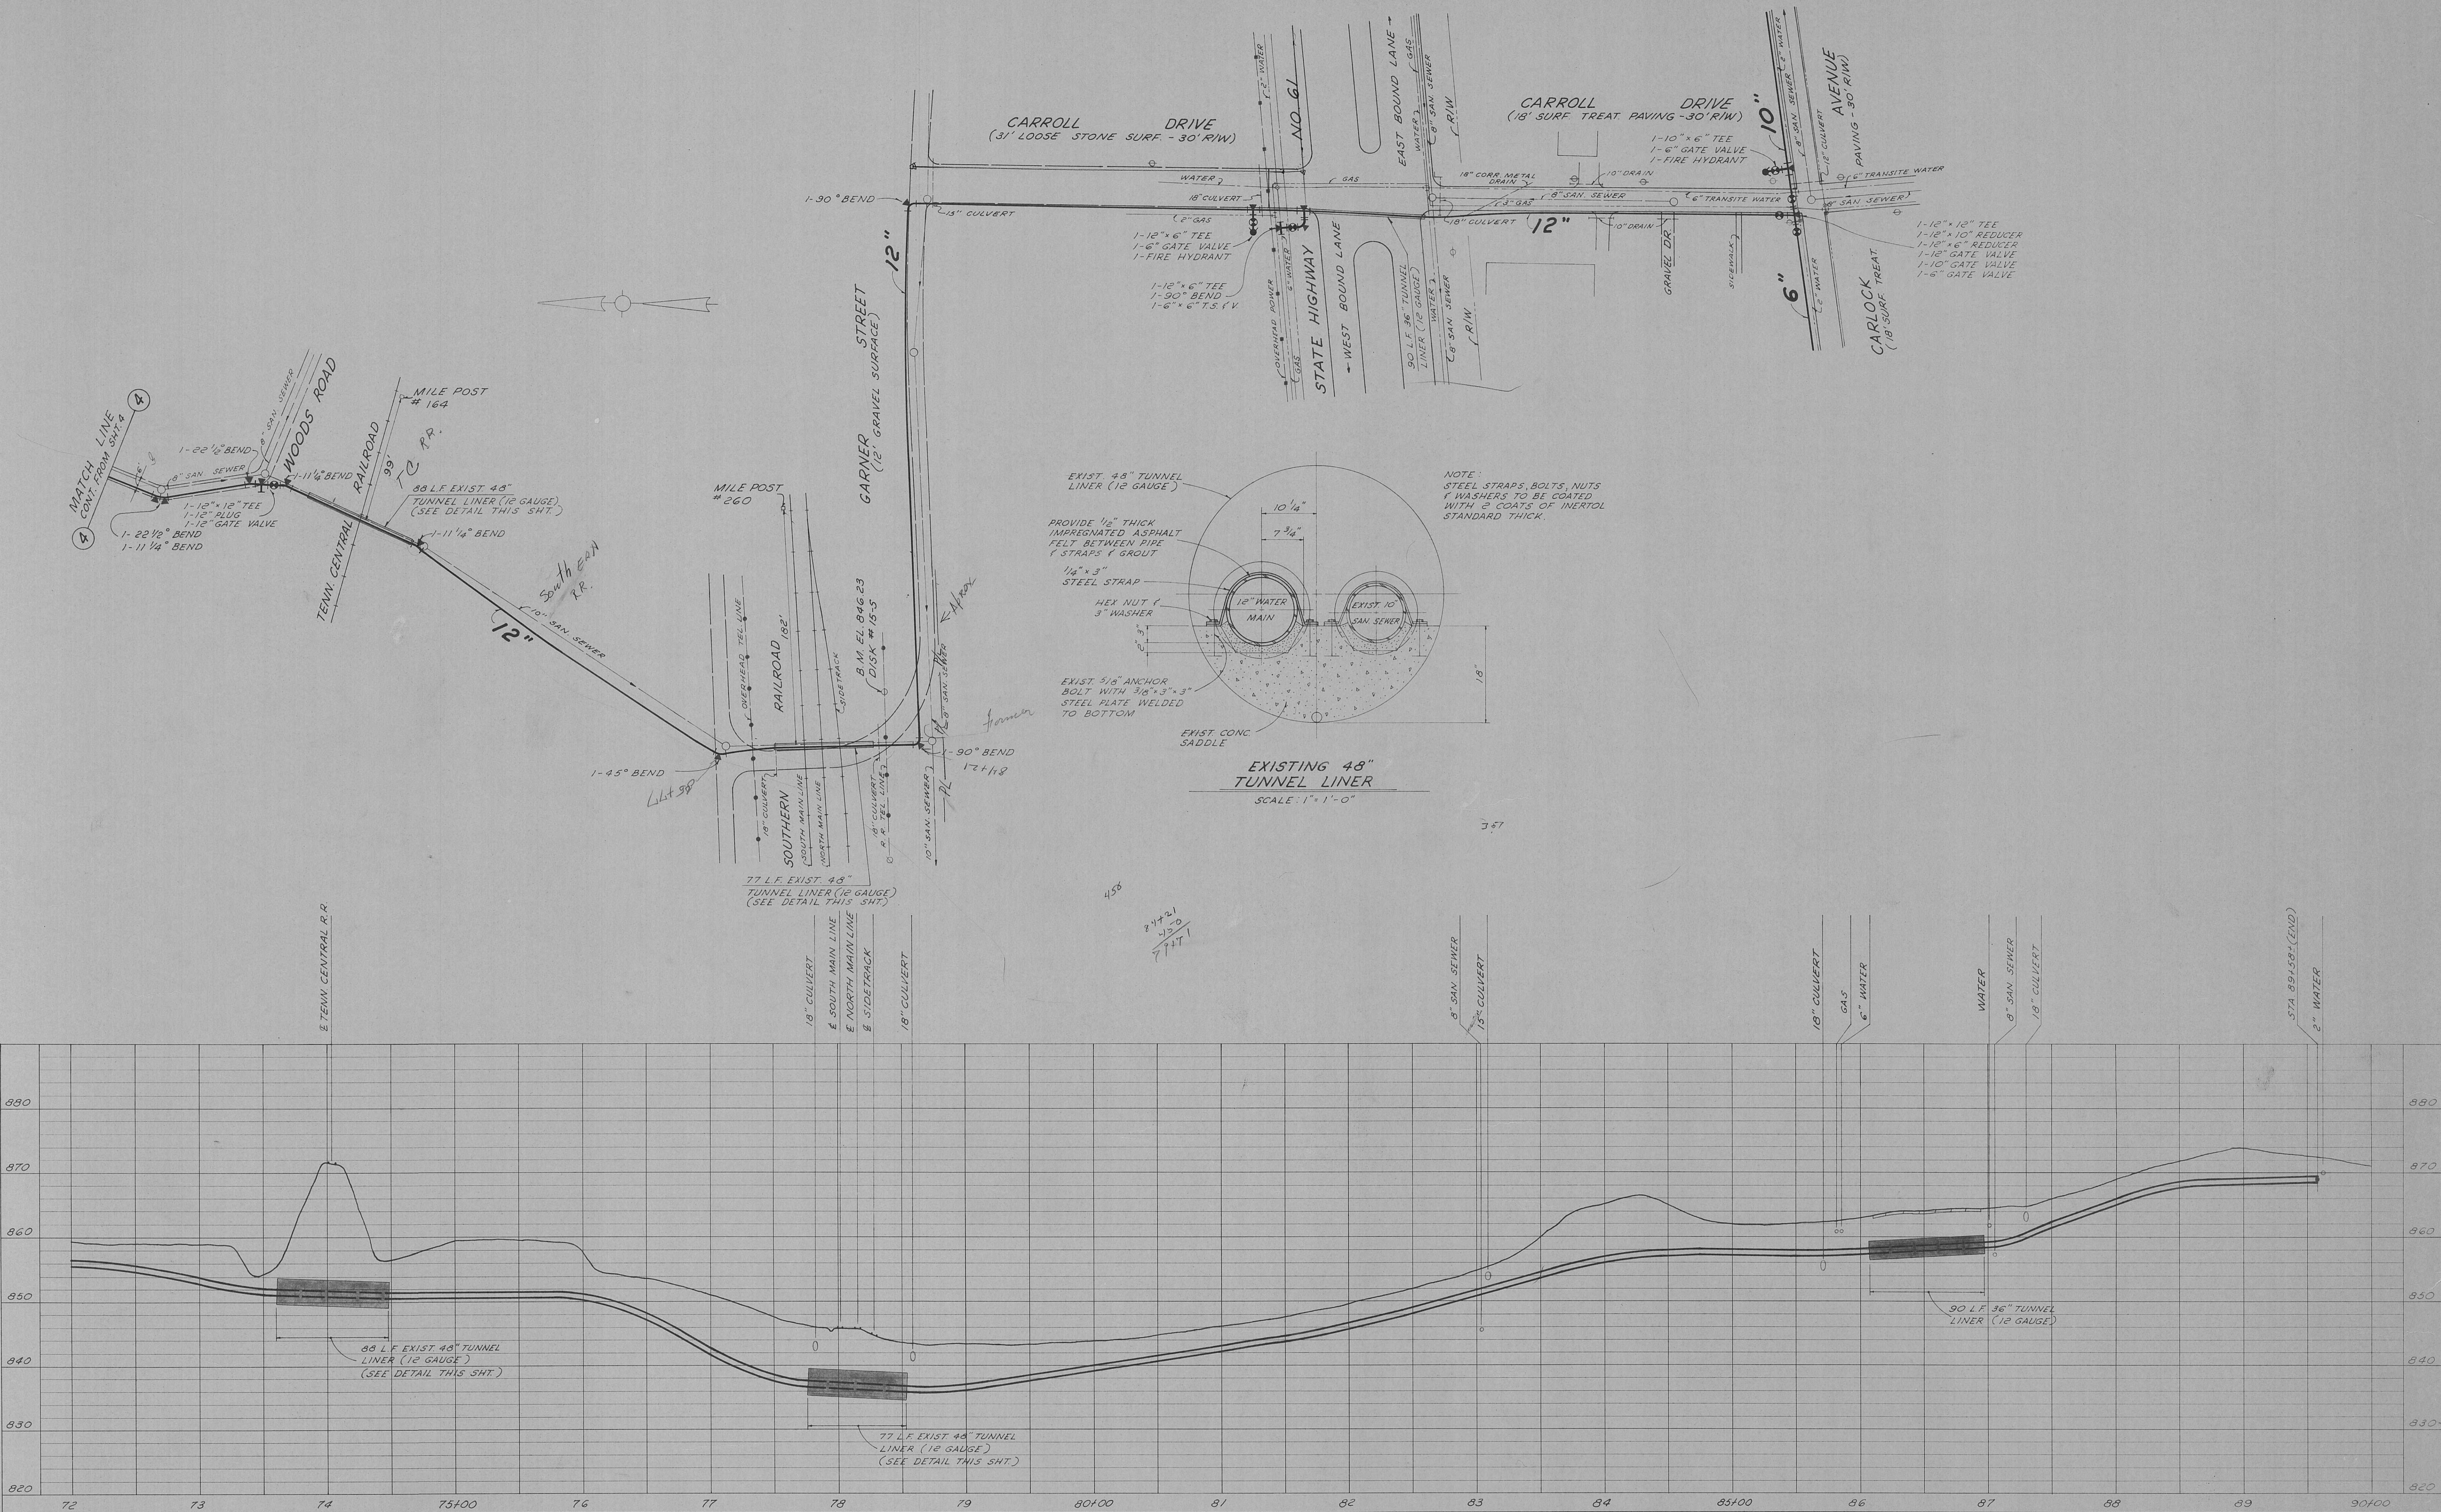

DIVISION ONE

CITY OF HARRIMAN, TENNESSEE
WATER SYSTEM IMPROVEMENTSEXTENSIONS TO
DISTRIBUTION SYSTEMSCALE
1"=50' HORIZ.
1"=10' VERT.
DATE
MAY, 1966WIEDEMAN AND SINGLETON
ENGINEERS
ATLANTA, GEORGIA5
OF
23

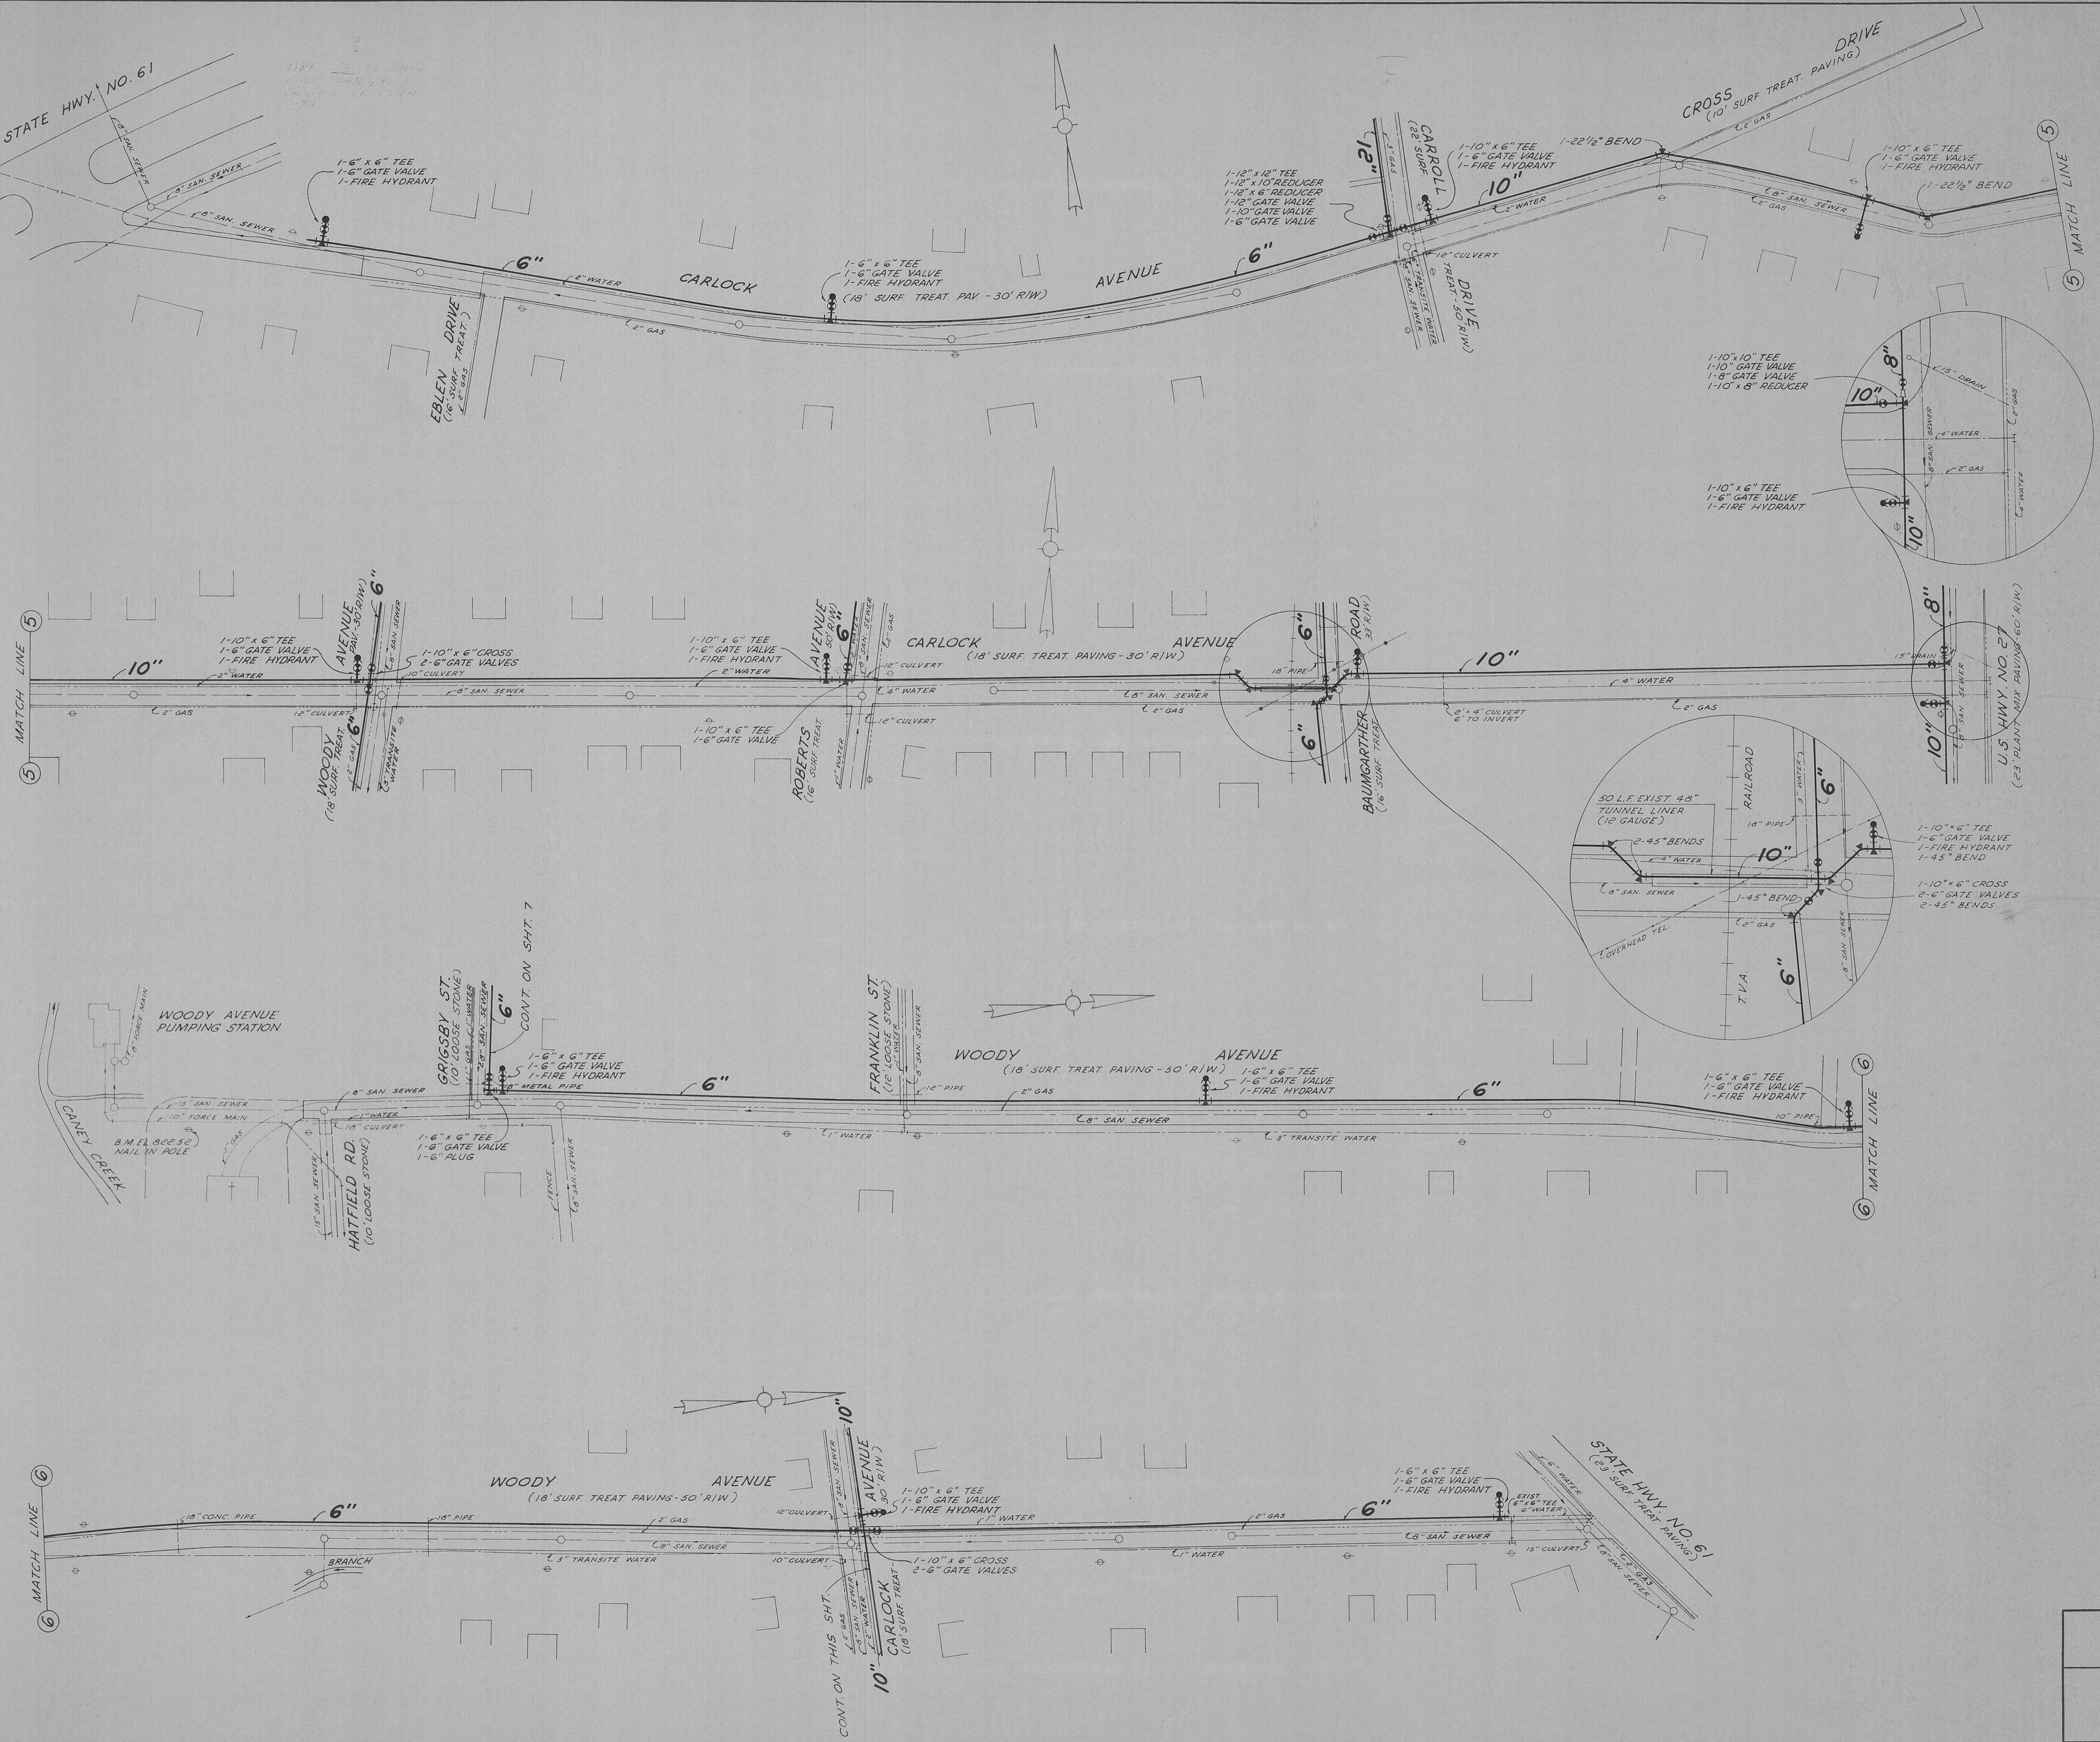

DIVISION ONE

CITY OF HARRIMAN, TENNESSEE
WATER SYSTEM IMPROVEMENTSEXTENSIONS TO
DISTRIBUTION SYSTEMSCALE
1'-50' HORZ.
DATE
MAY, 1966
WIEDEMAN AND SINGLETON
ENGINEERS
ATLANTA GEORGIA

6

