

**SANITARY SEWERAGE
FACILITIES
FOR
CITY OF
HARRIMAN, TENNESSEE**

BLACK, CROW & EIDSNESS, INC.
ENGINEERS

ATLANTA, GEORGIA


GAINESVILLE, FLORIDA

These Plans and Specifications submitted
in connection with the Application for a Federal
Order for the construction of treatment works
under the provisions of the Federal Water Pollution
Control Act (23 USC 466 et seq.) and the regulations
promulgated thereunder have been reviewed.

Hughes W. Miller *Dec 3 1968*
(Engineering)
(Date)

and are herewith APPROVED:
Asst. Director *12/5/68*
Regional Construction Grants Program
Director, FWPCA, SE REGION, ATLANTA, GA.
(Date)





**PHASE II OF
MODIFICATIONS TO
EFFLUENT PUMPING SYSTEM
PROJECT NO. 479-68-2**




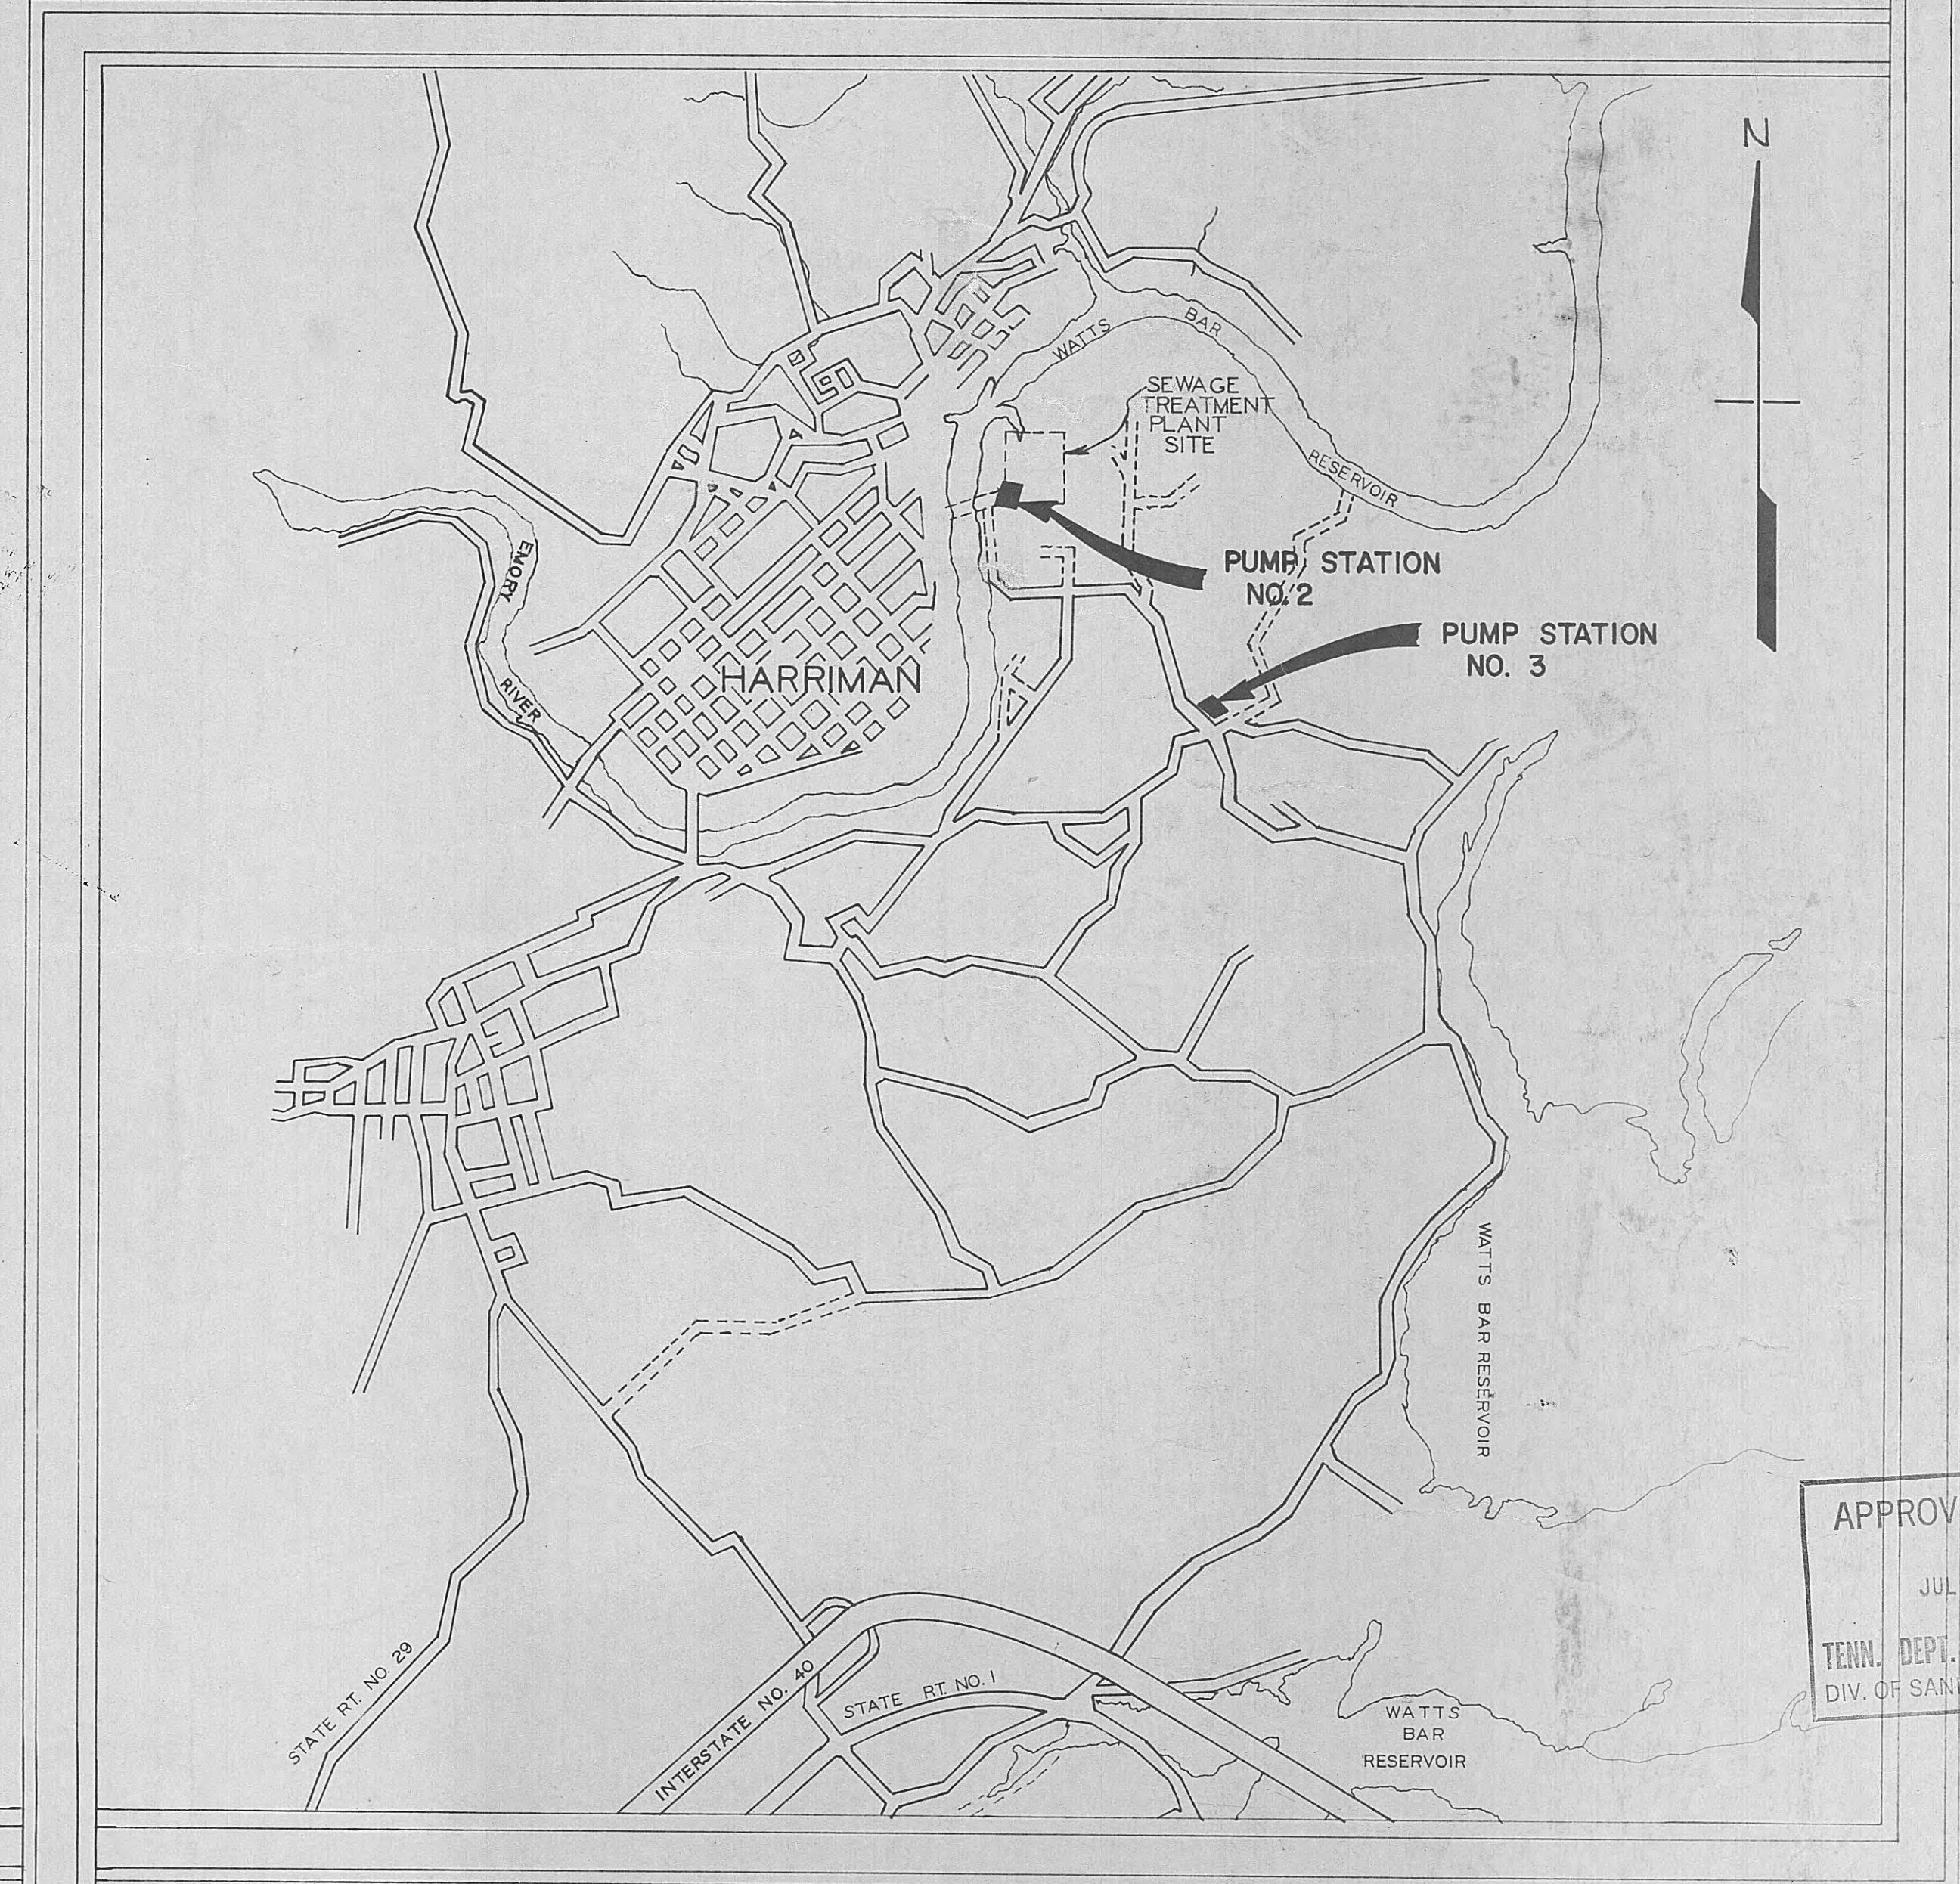


APPROVED
JUL 16 1968
TENNESSEE DEPARTMENT OF PUBLIC HEALTH
DIVISION OF SANITARY ENGINEERING
J. Julian L. Fleming Director


FOR APPROVAL

7/16/68 2-7

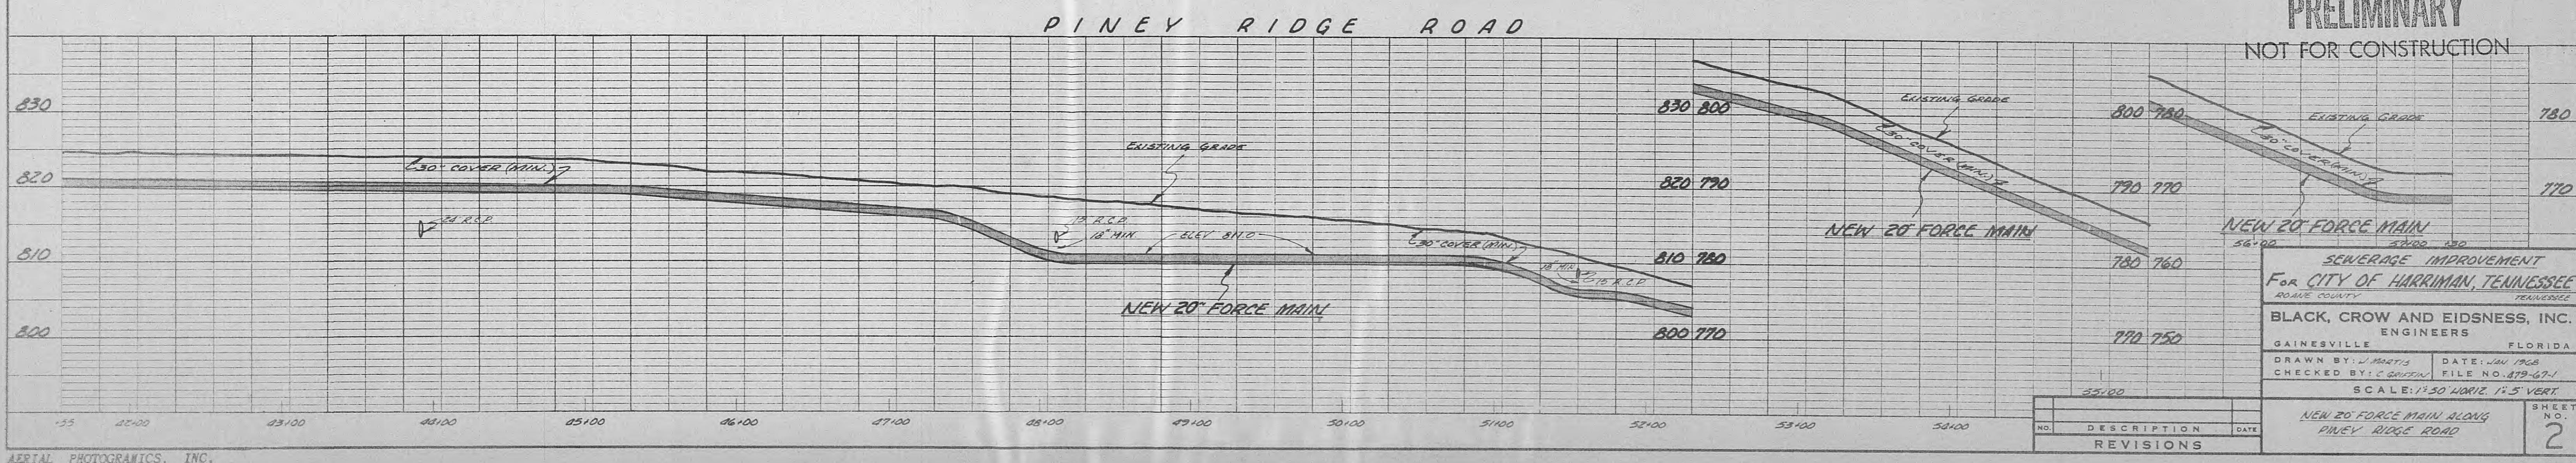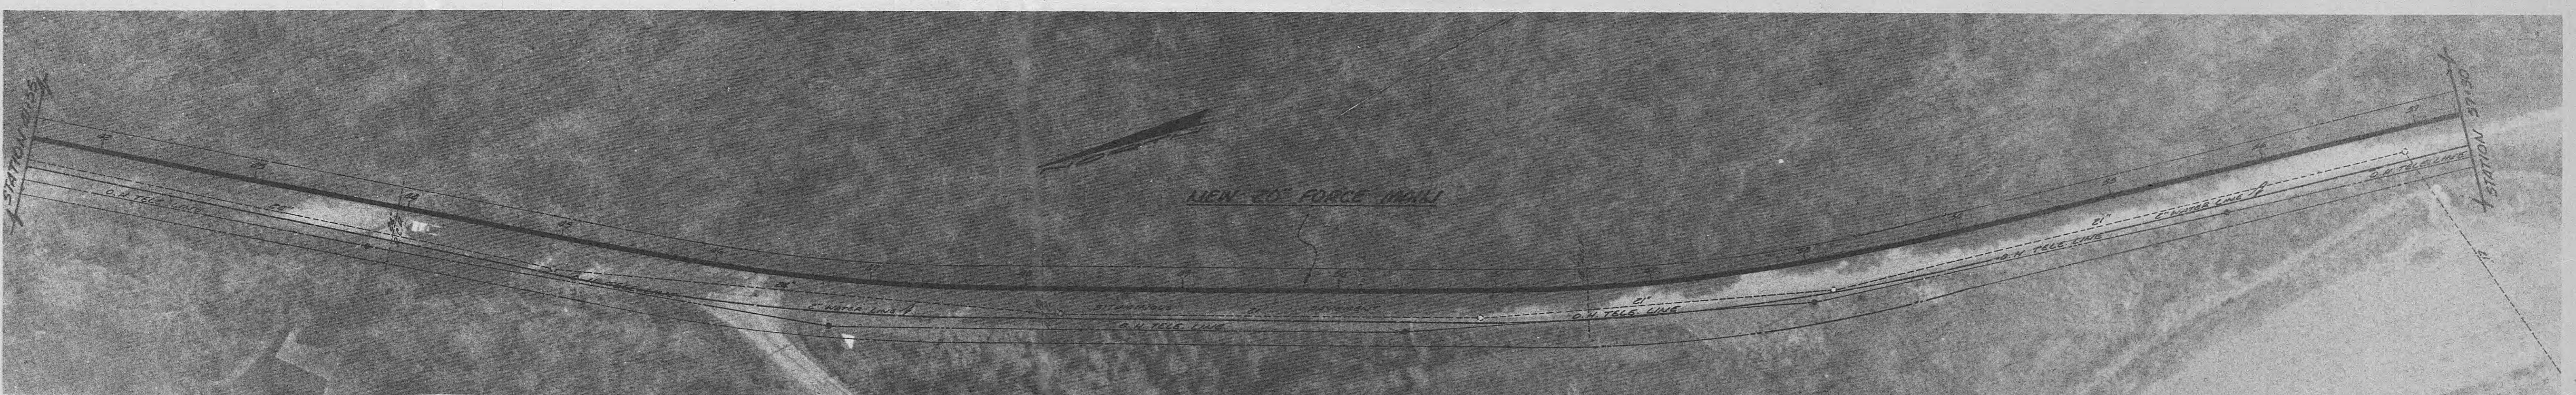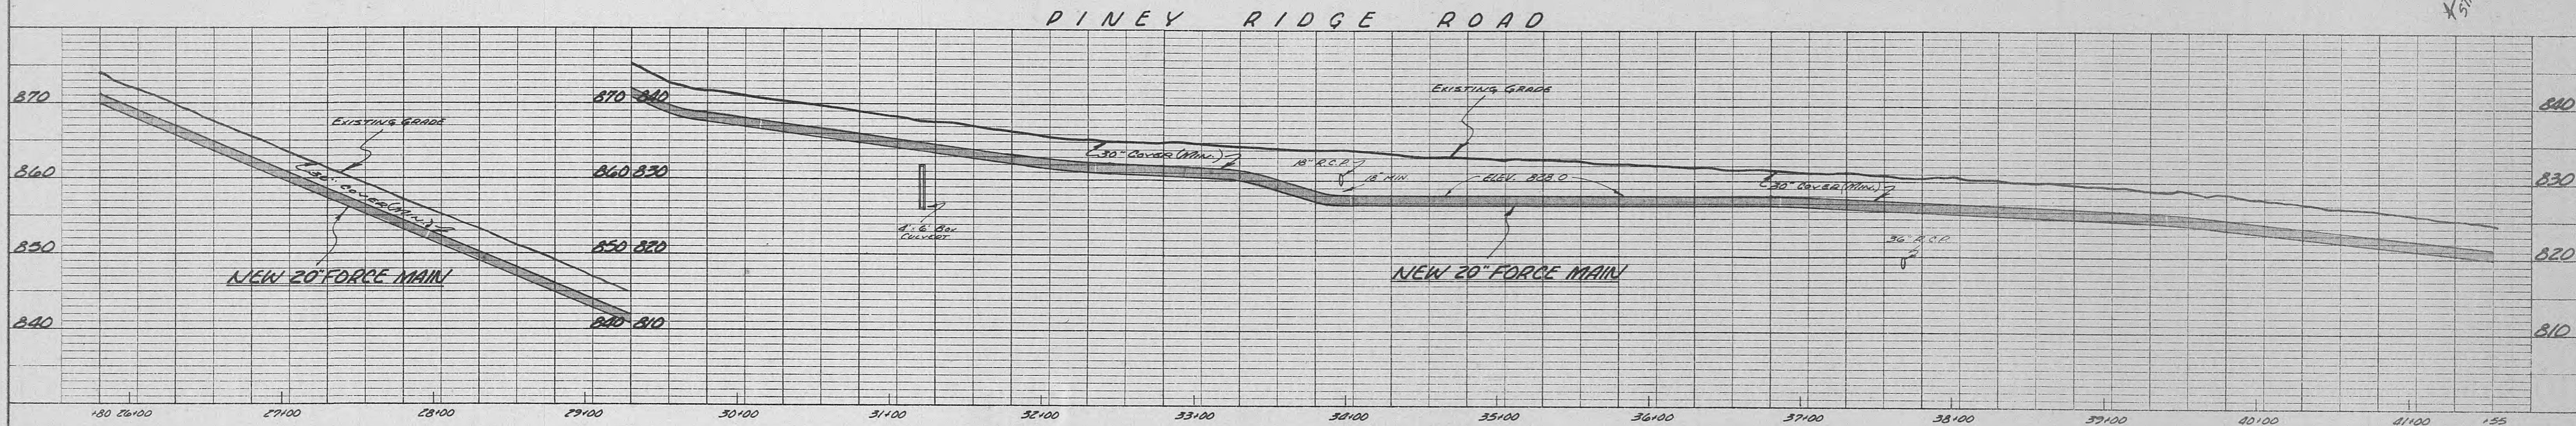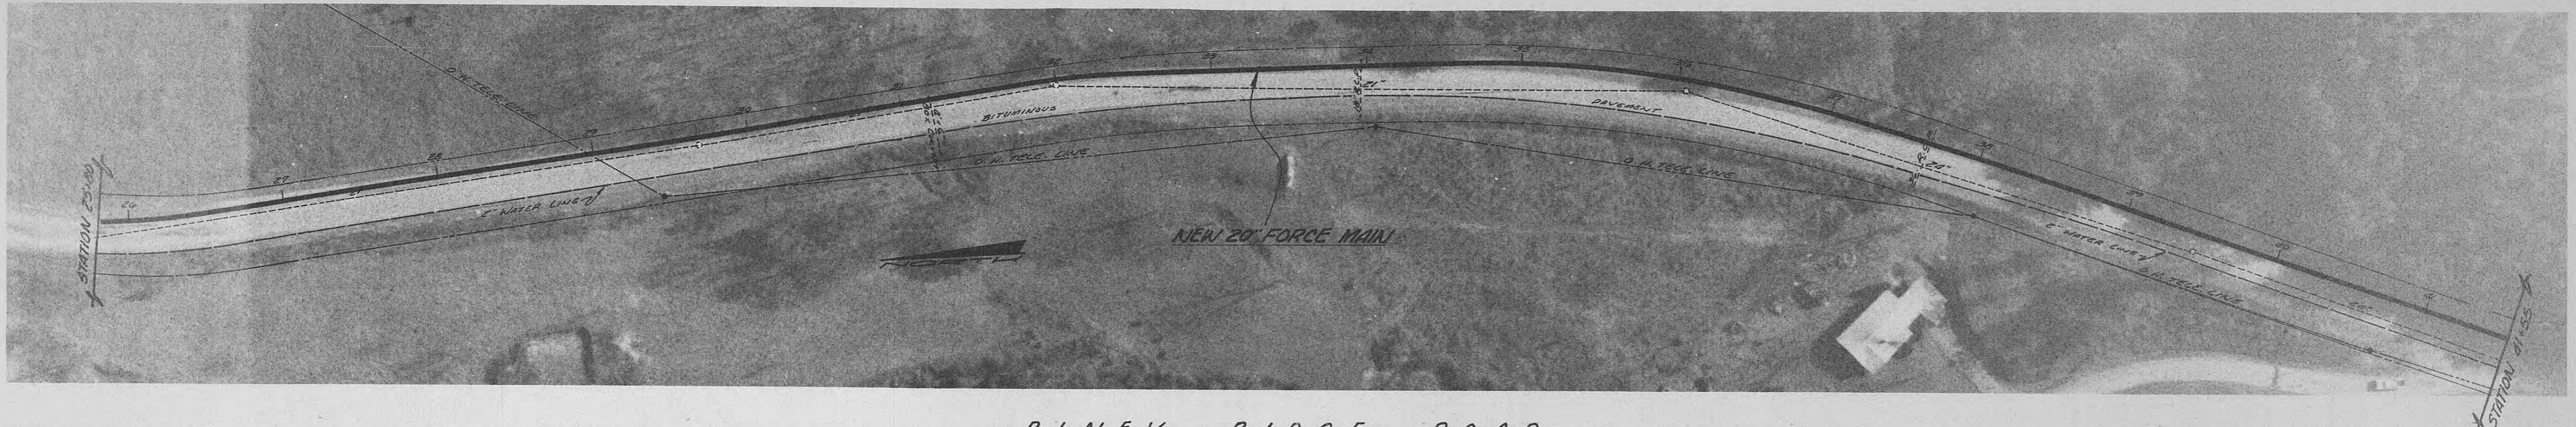

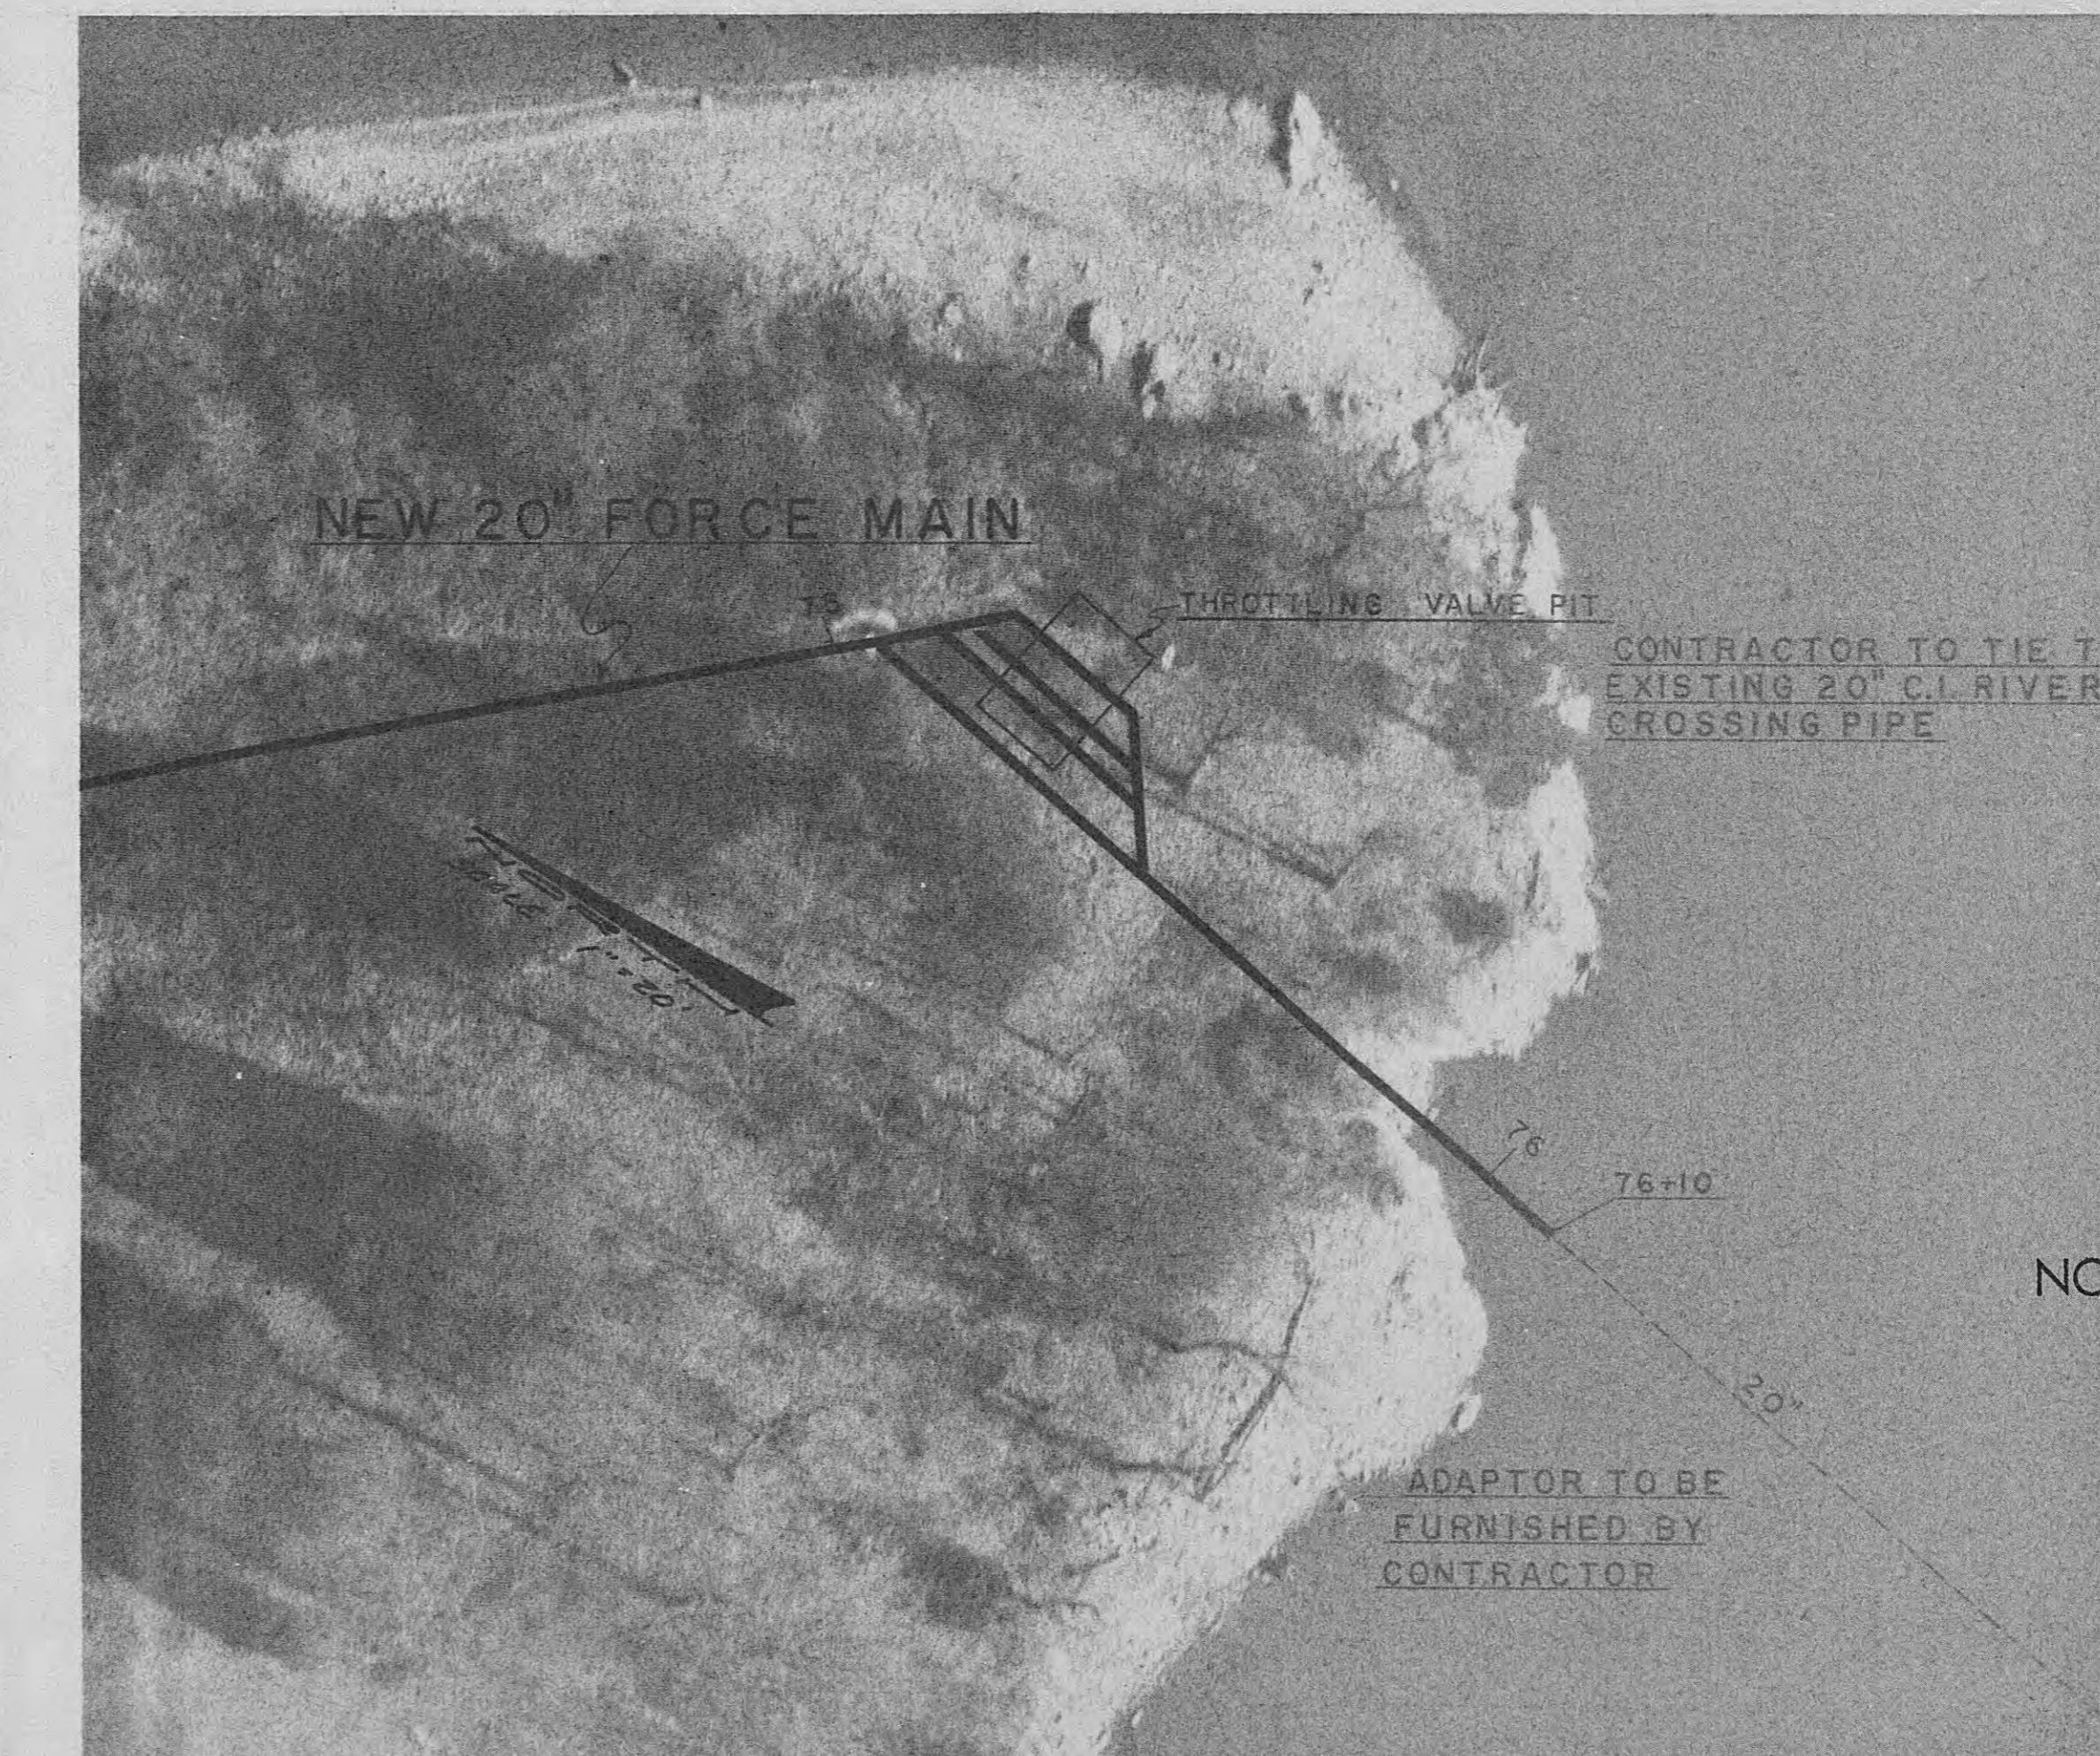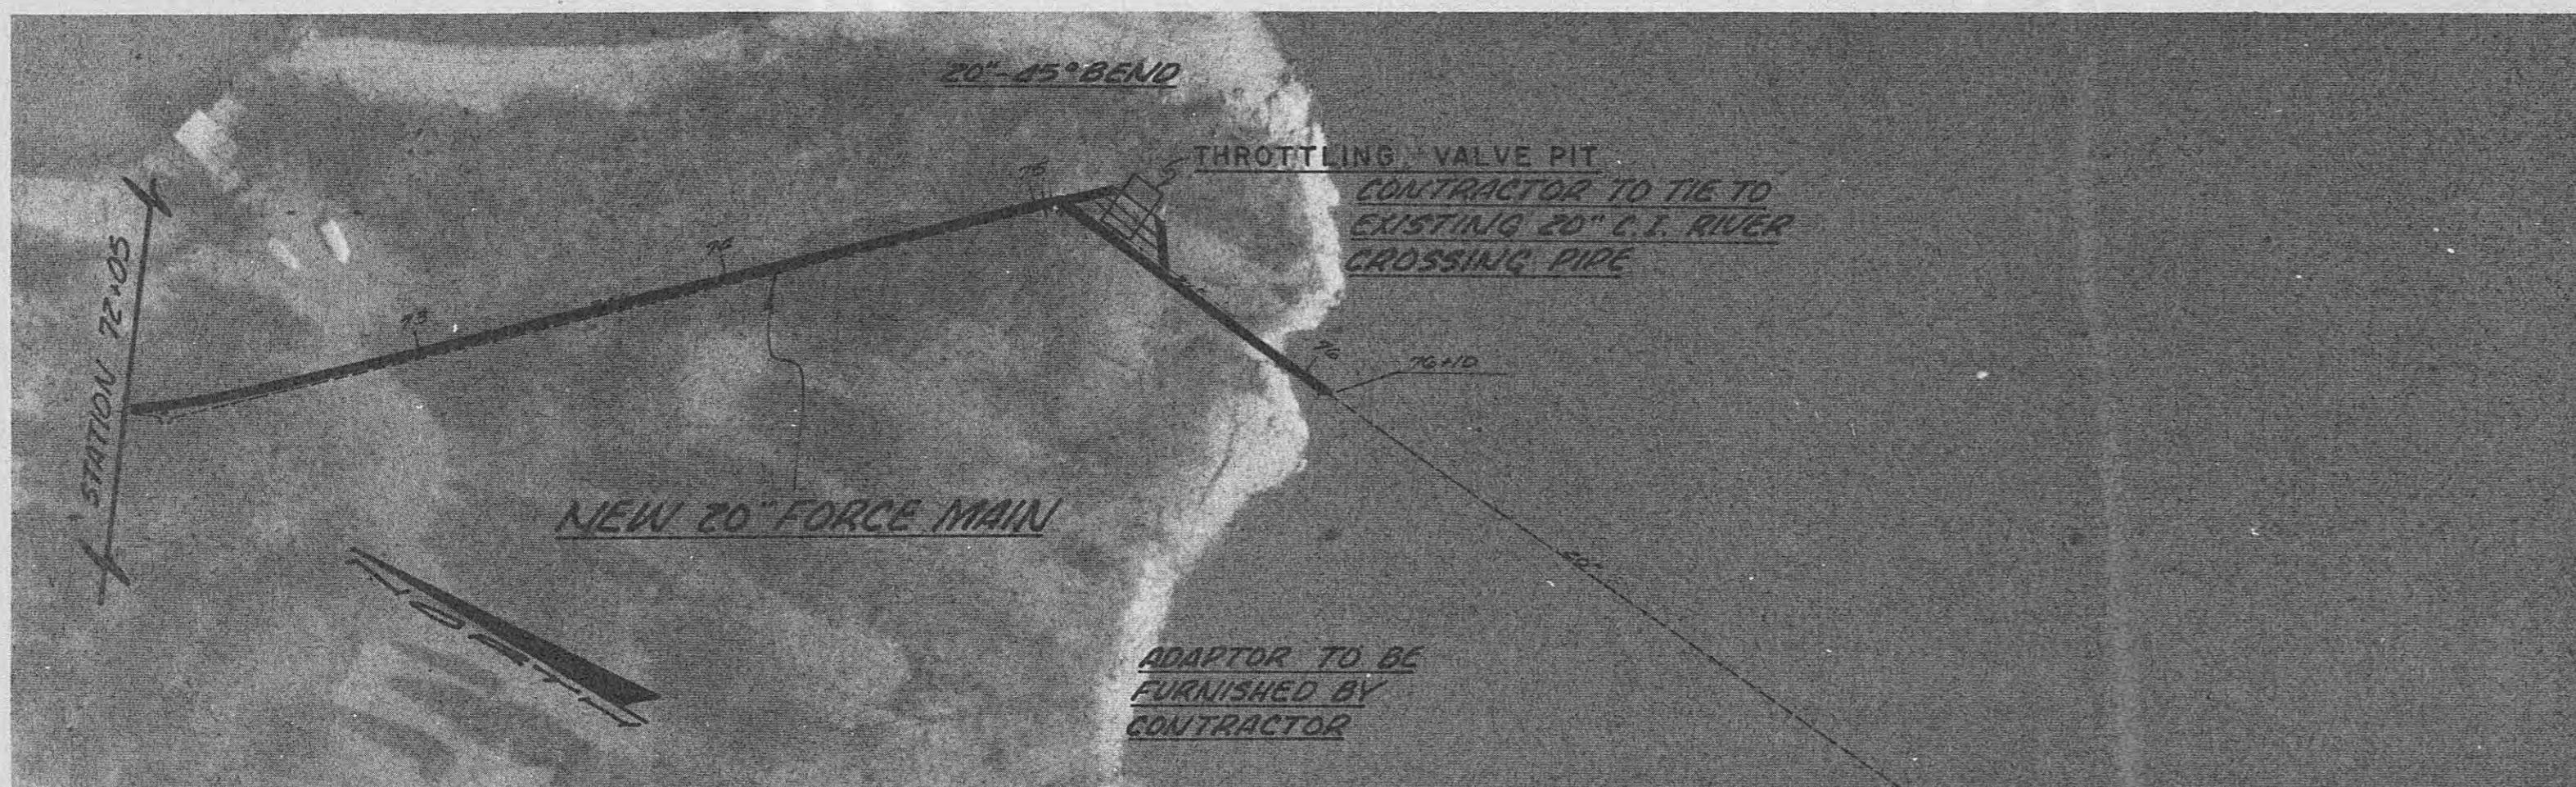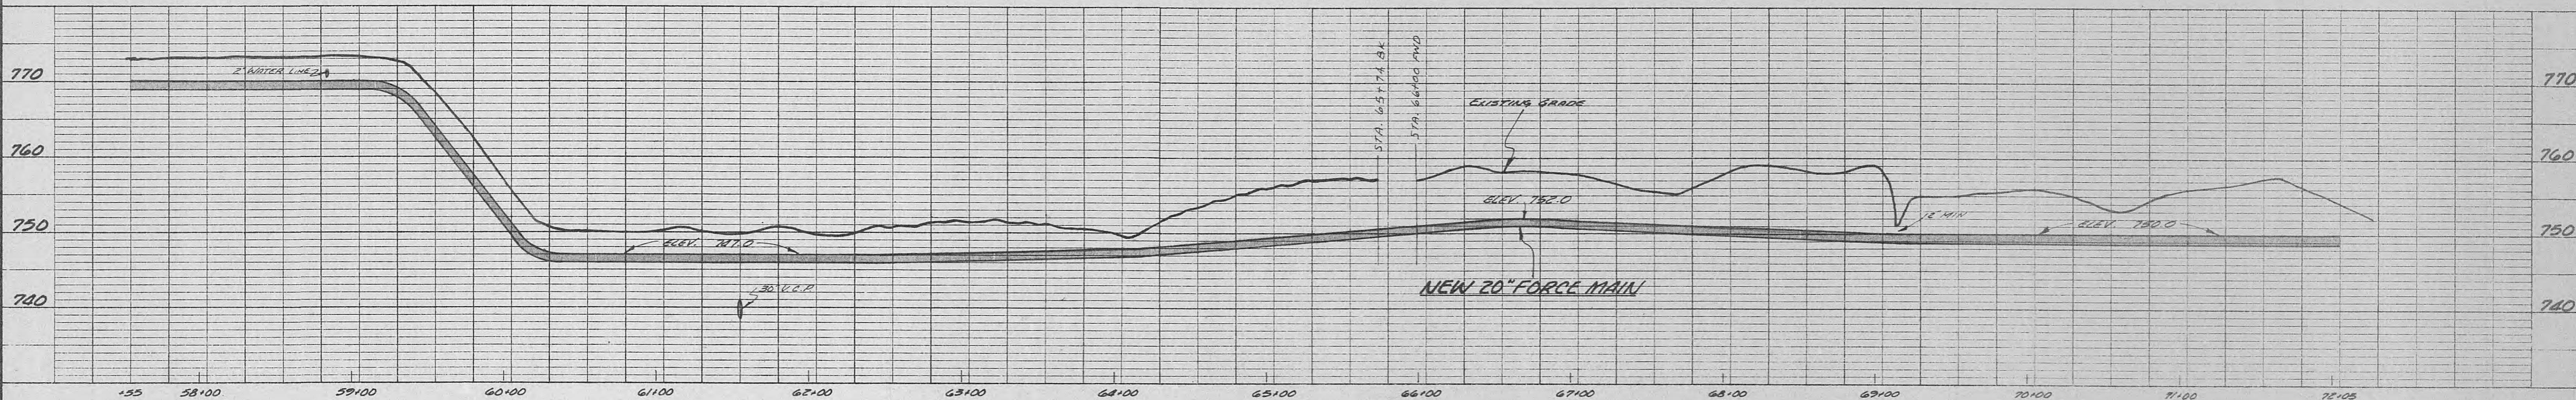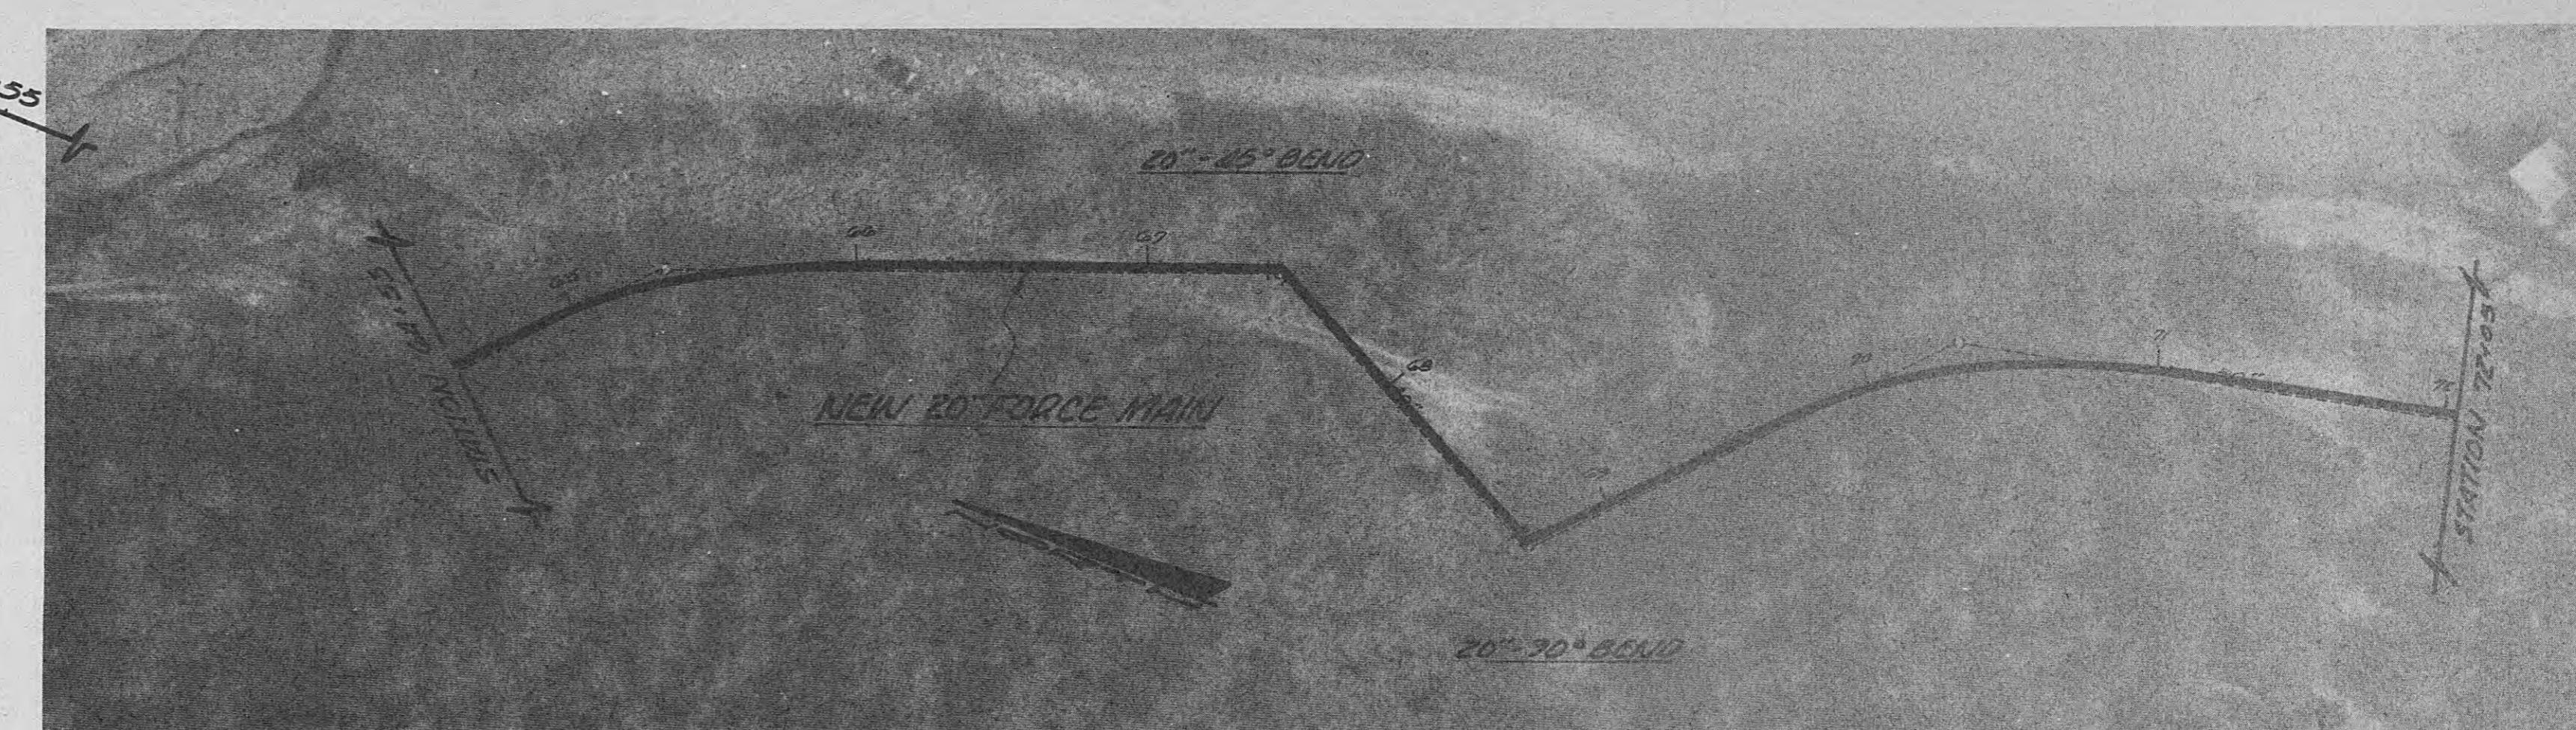


**PRELIMINARY
NOT FOR CONSTRUCTION**

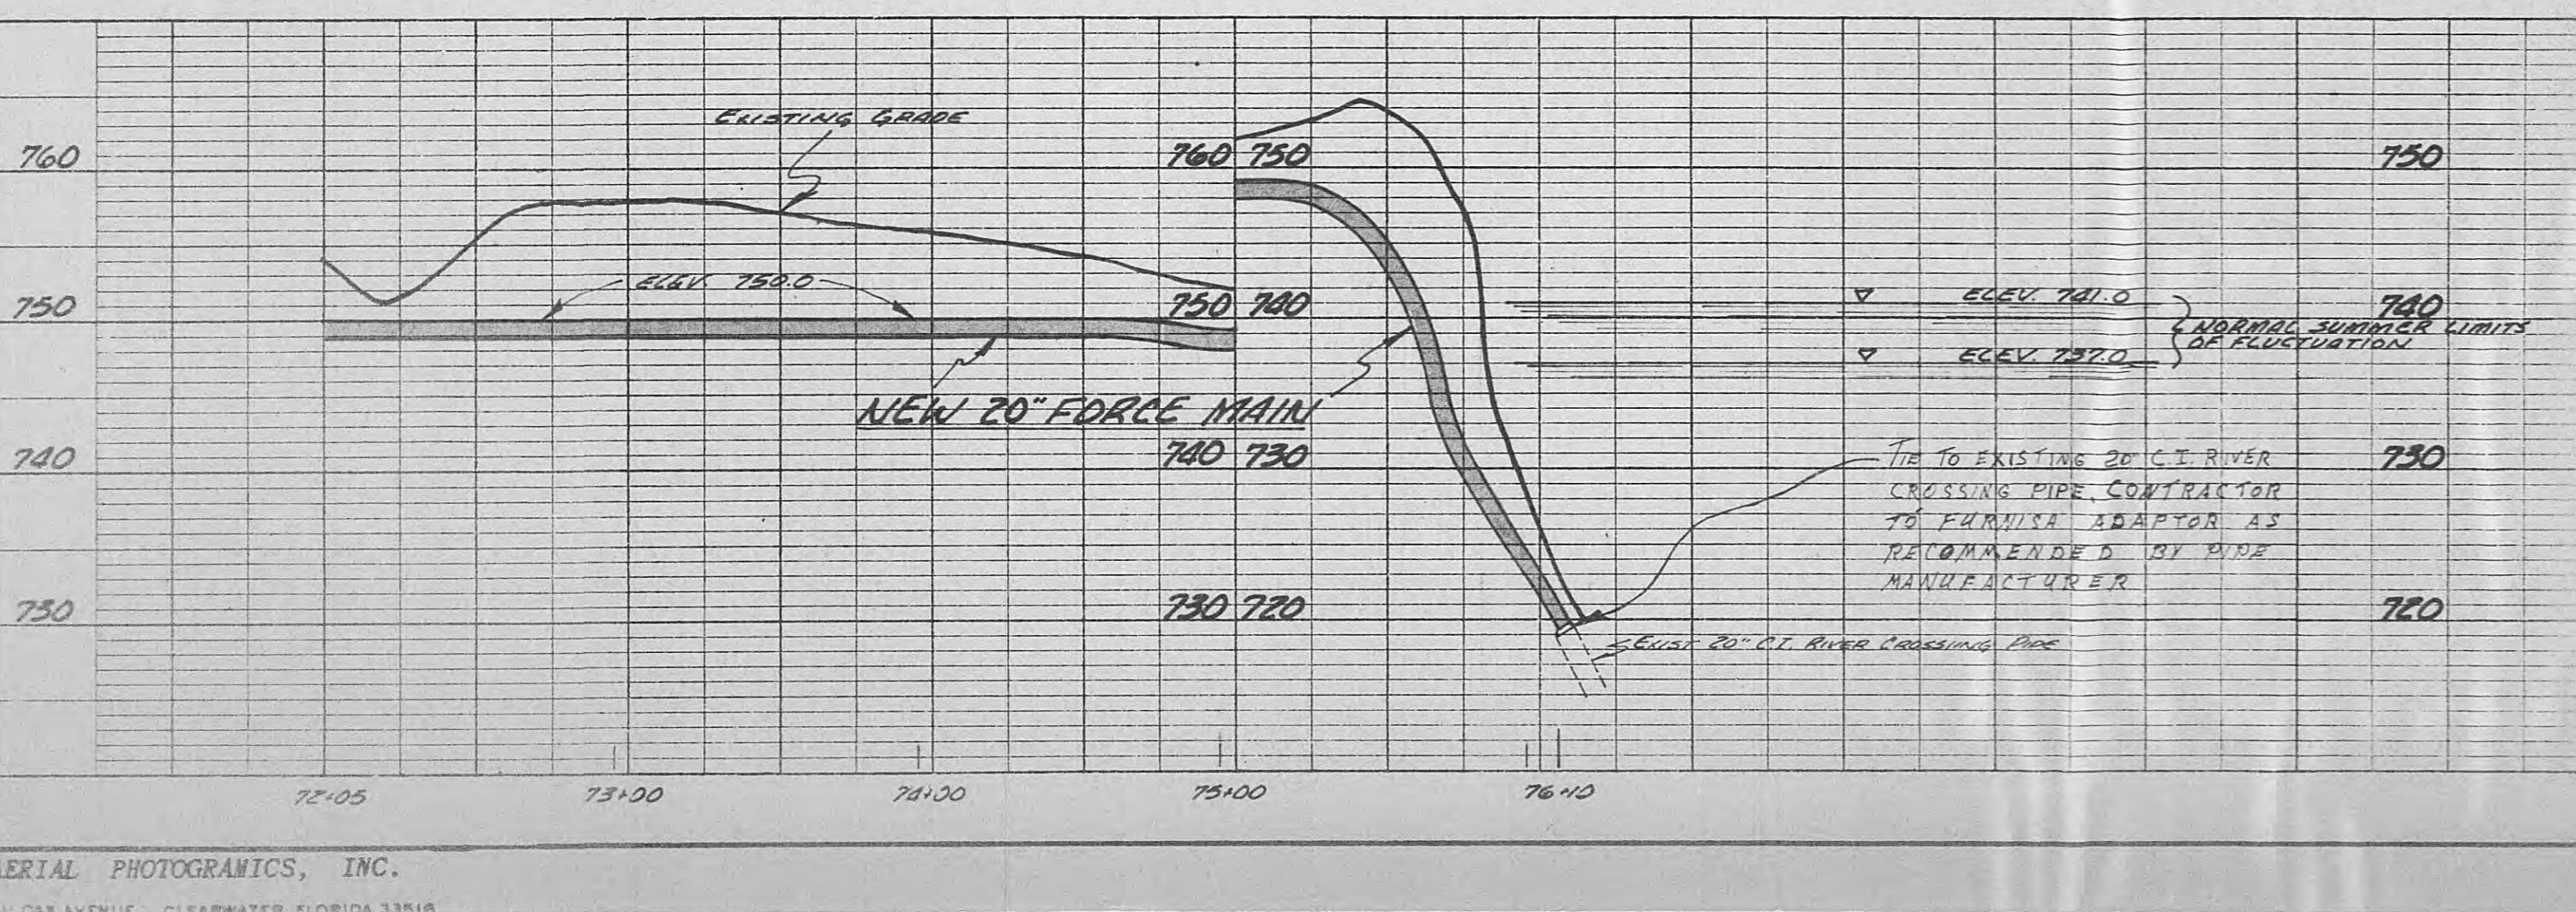


SEWERAGE IMPROVEMENTS
FOR CITY OF HARRIMAN, TENNESSEE
ROCKY COUNTY, TENNESSEE
BLACK, CROW AND EIDSNESS, INC.
ENGINEERS
GAINESVILLE, FLORIDA
DRAWN BY: J. MARTIS DATE: JAN. 1968
CHECKED BY: C. GRIFFIN FILE NO. 472-67-1
SCALE: 1/50 100' X 10' VERT
AERIAL PHOTOGRAPHICS, INC.
500 OAK AVENUE, CLEARWATER, FLORIDA 33516
SHEET NO. 3

NEW 20" FORCE MAIN ALONG
PINEY RIDGE ROAD TO TENNESSEE
RIVER

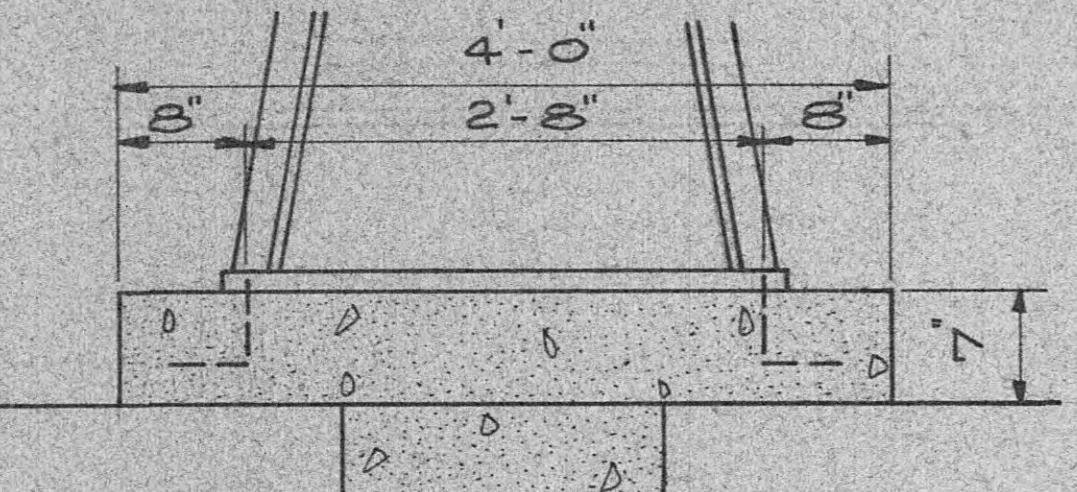

PUMP PAD DETAIL

SCALE 1" = 1'-0"

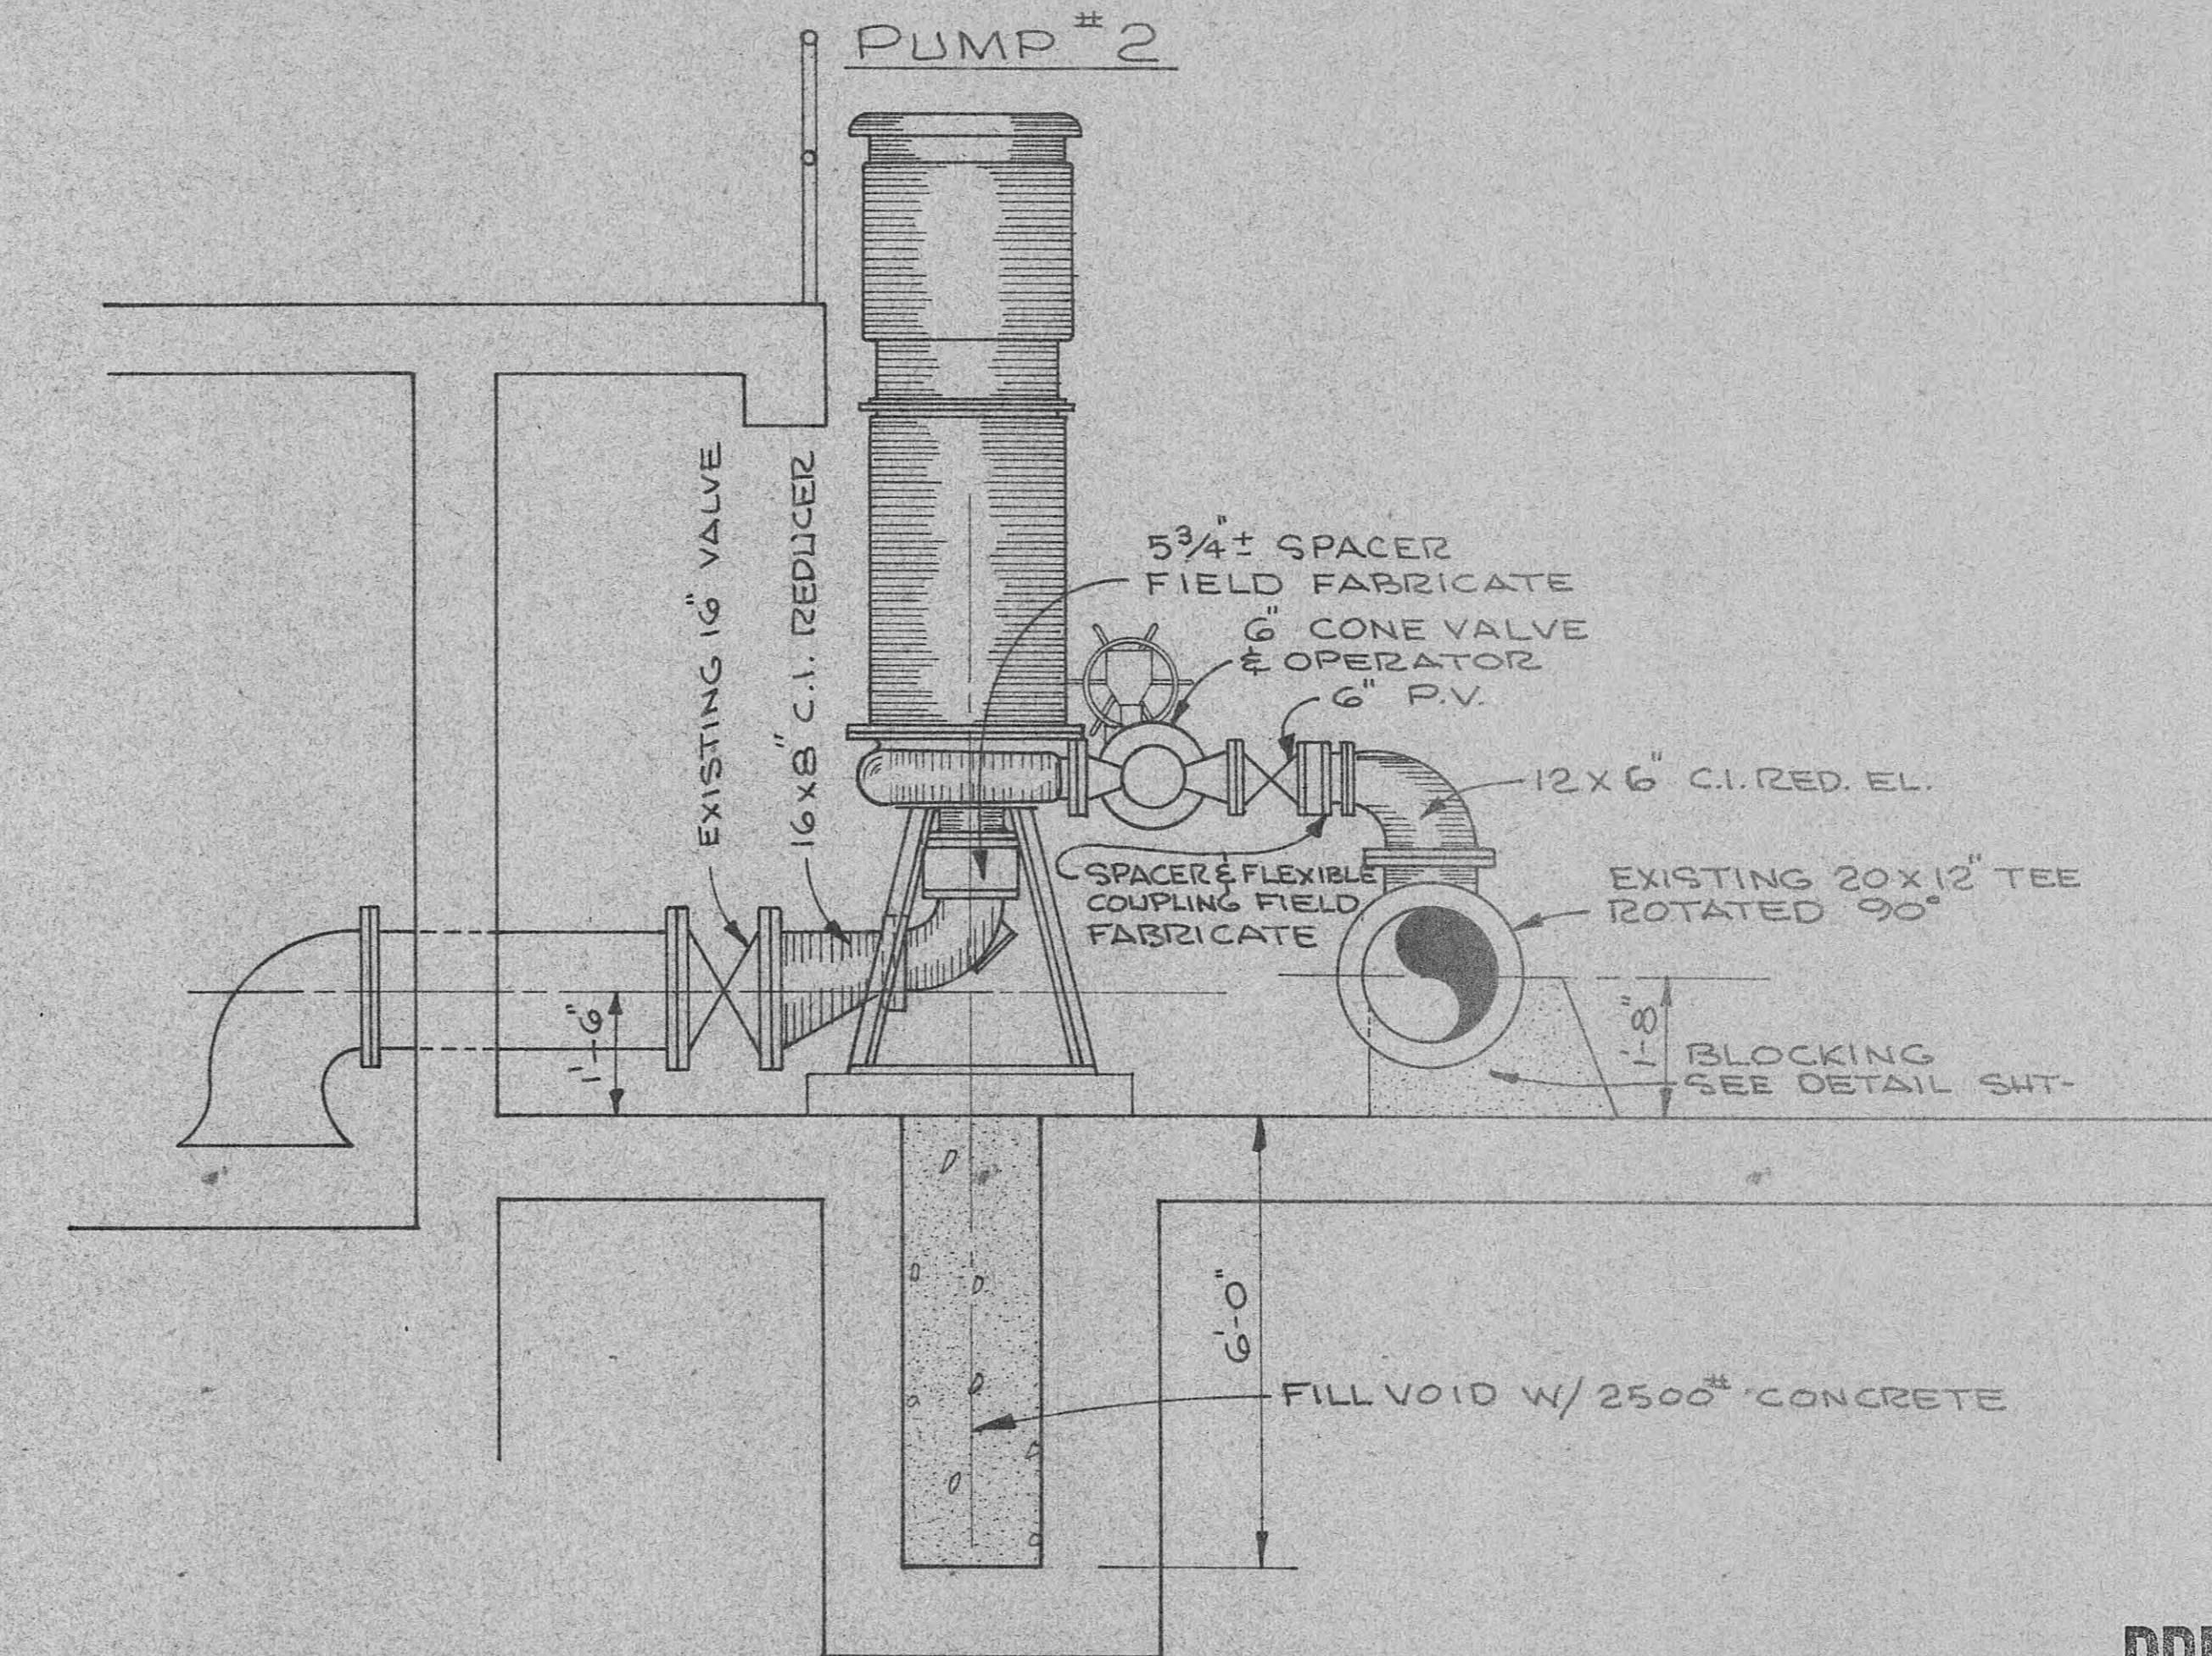


PRELIMINARY

NOT FOR CONSTRUCTION

SECTION "A"-A"


SCALE 1/2" = 1'-0"

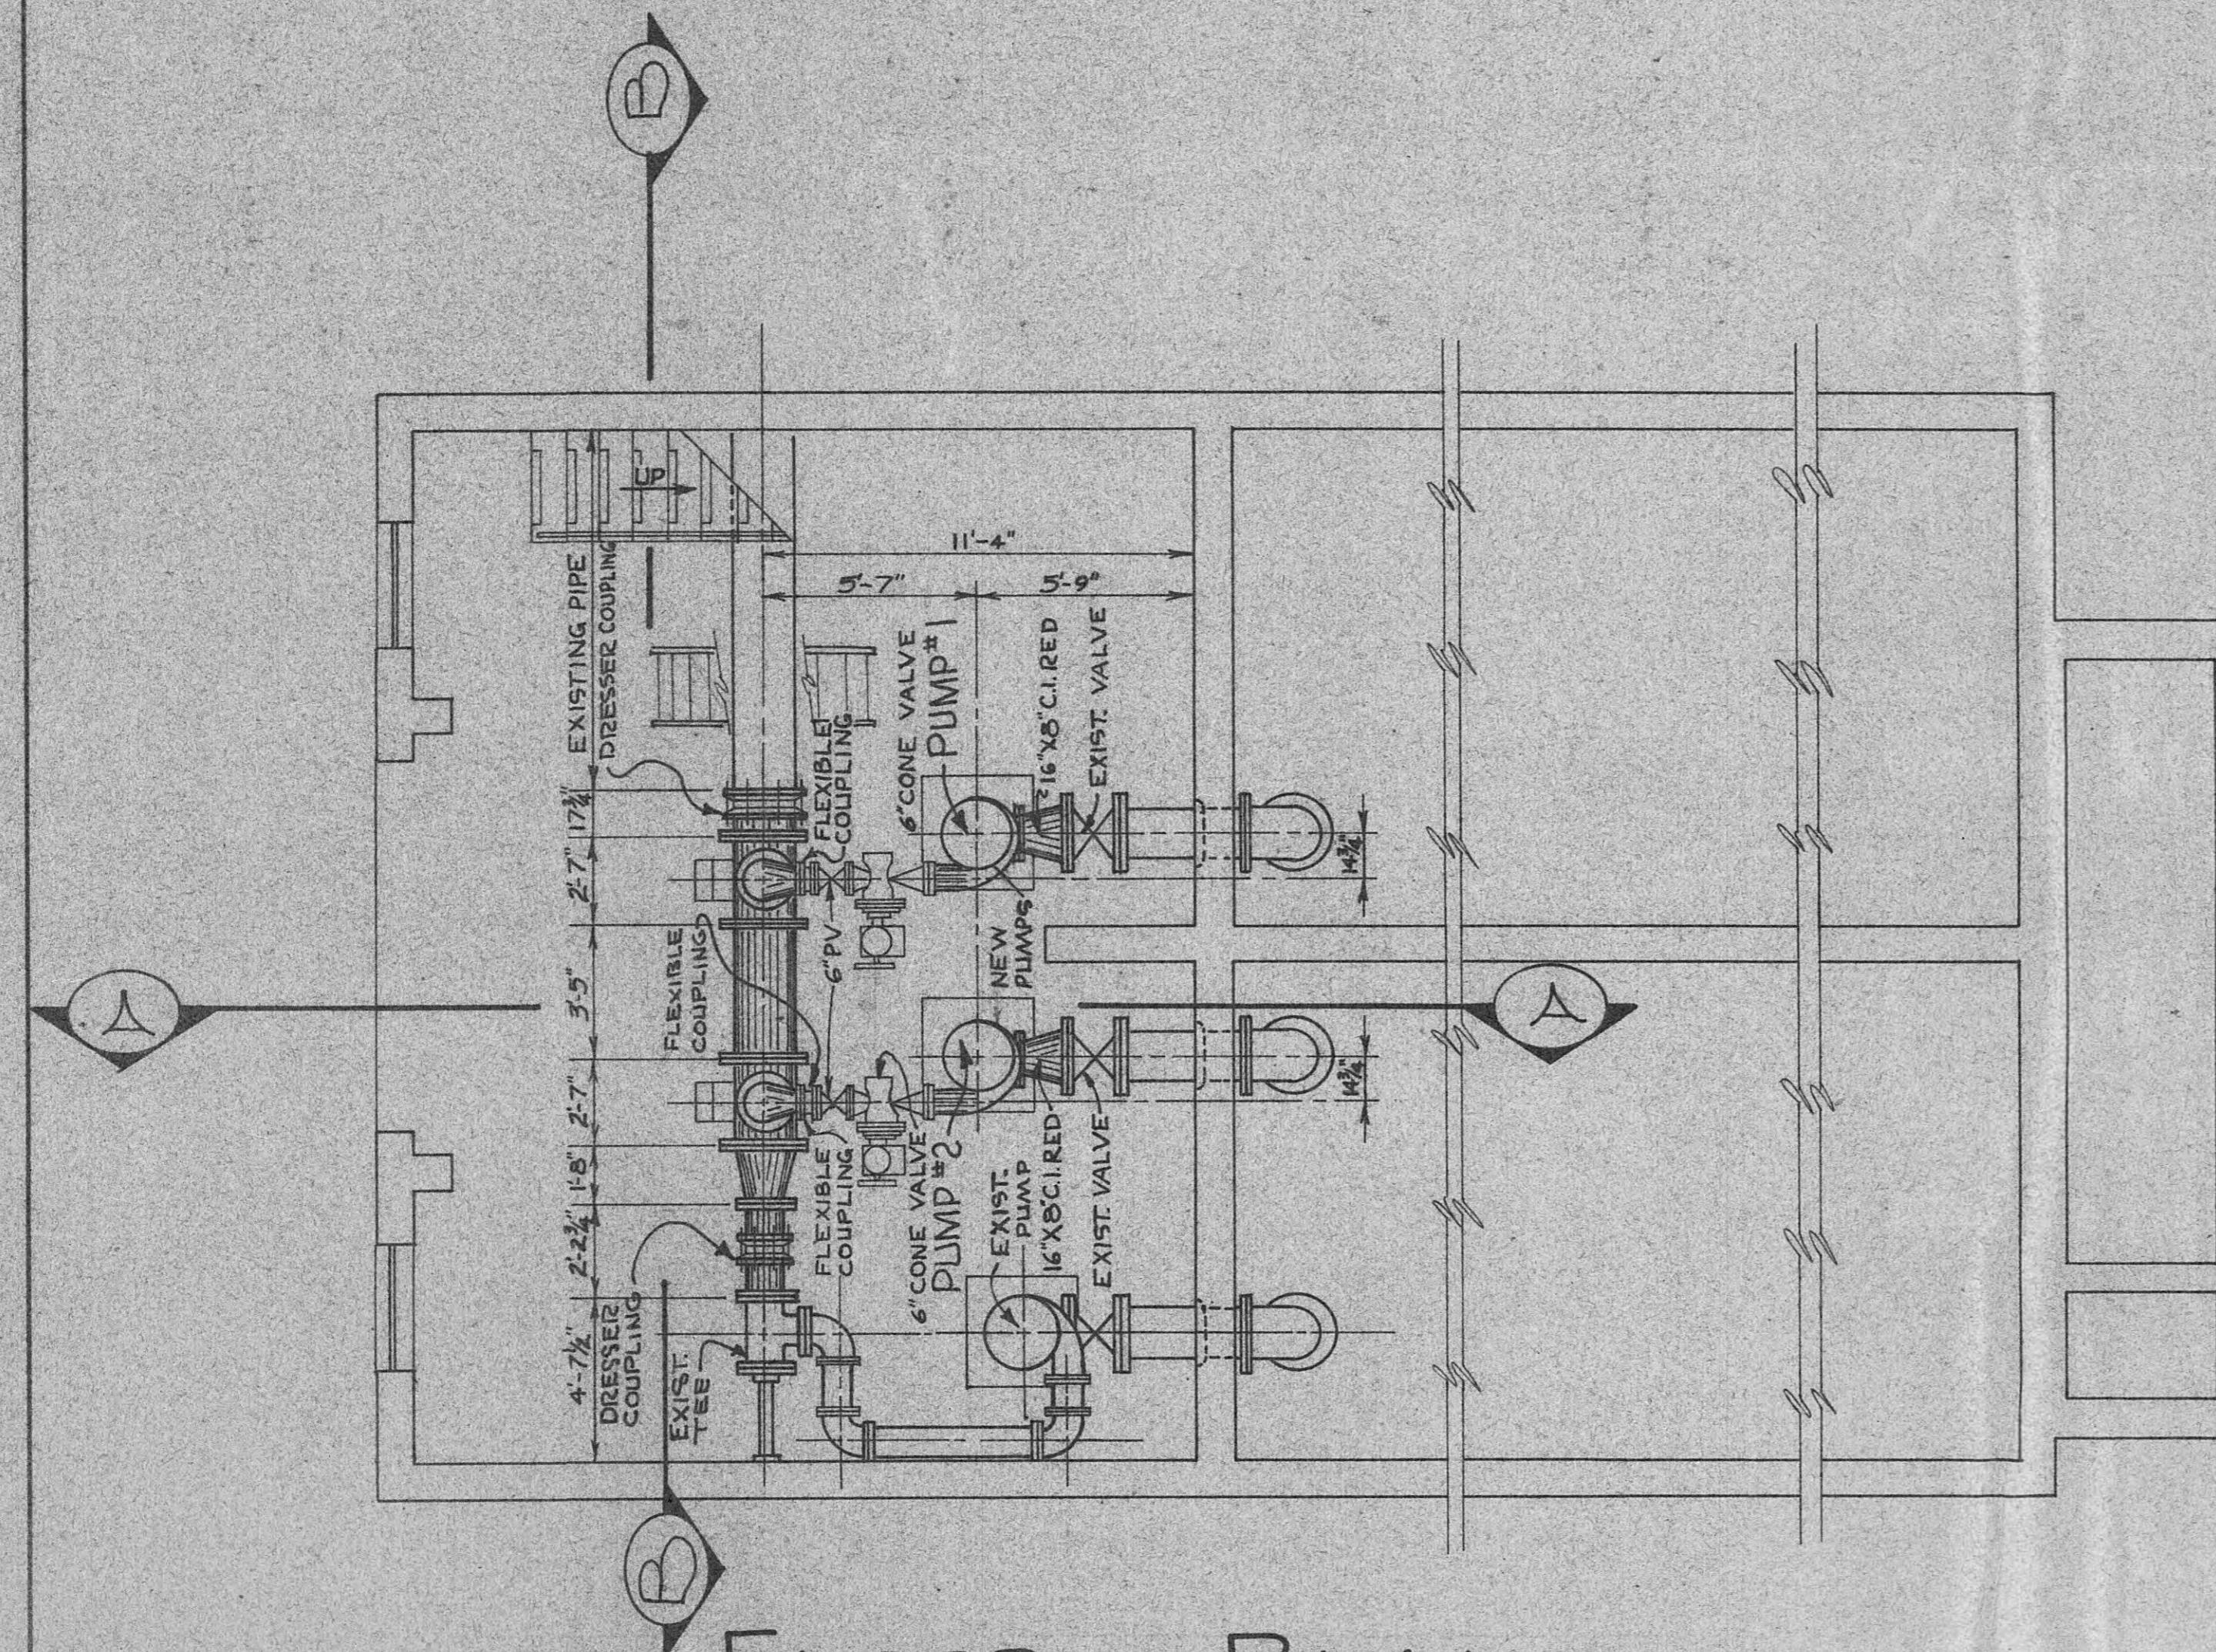

FLOOR PLAN

SCALE 1/4" = 1'-0"

MODIFICATIONS TO EXISTING PUMP STATION NO. 3

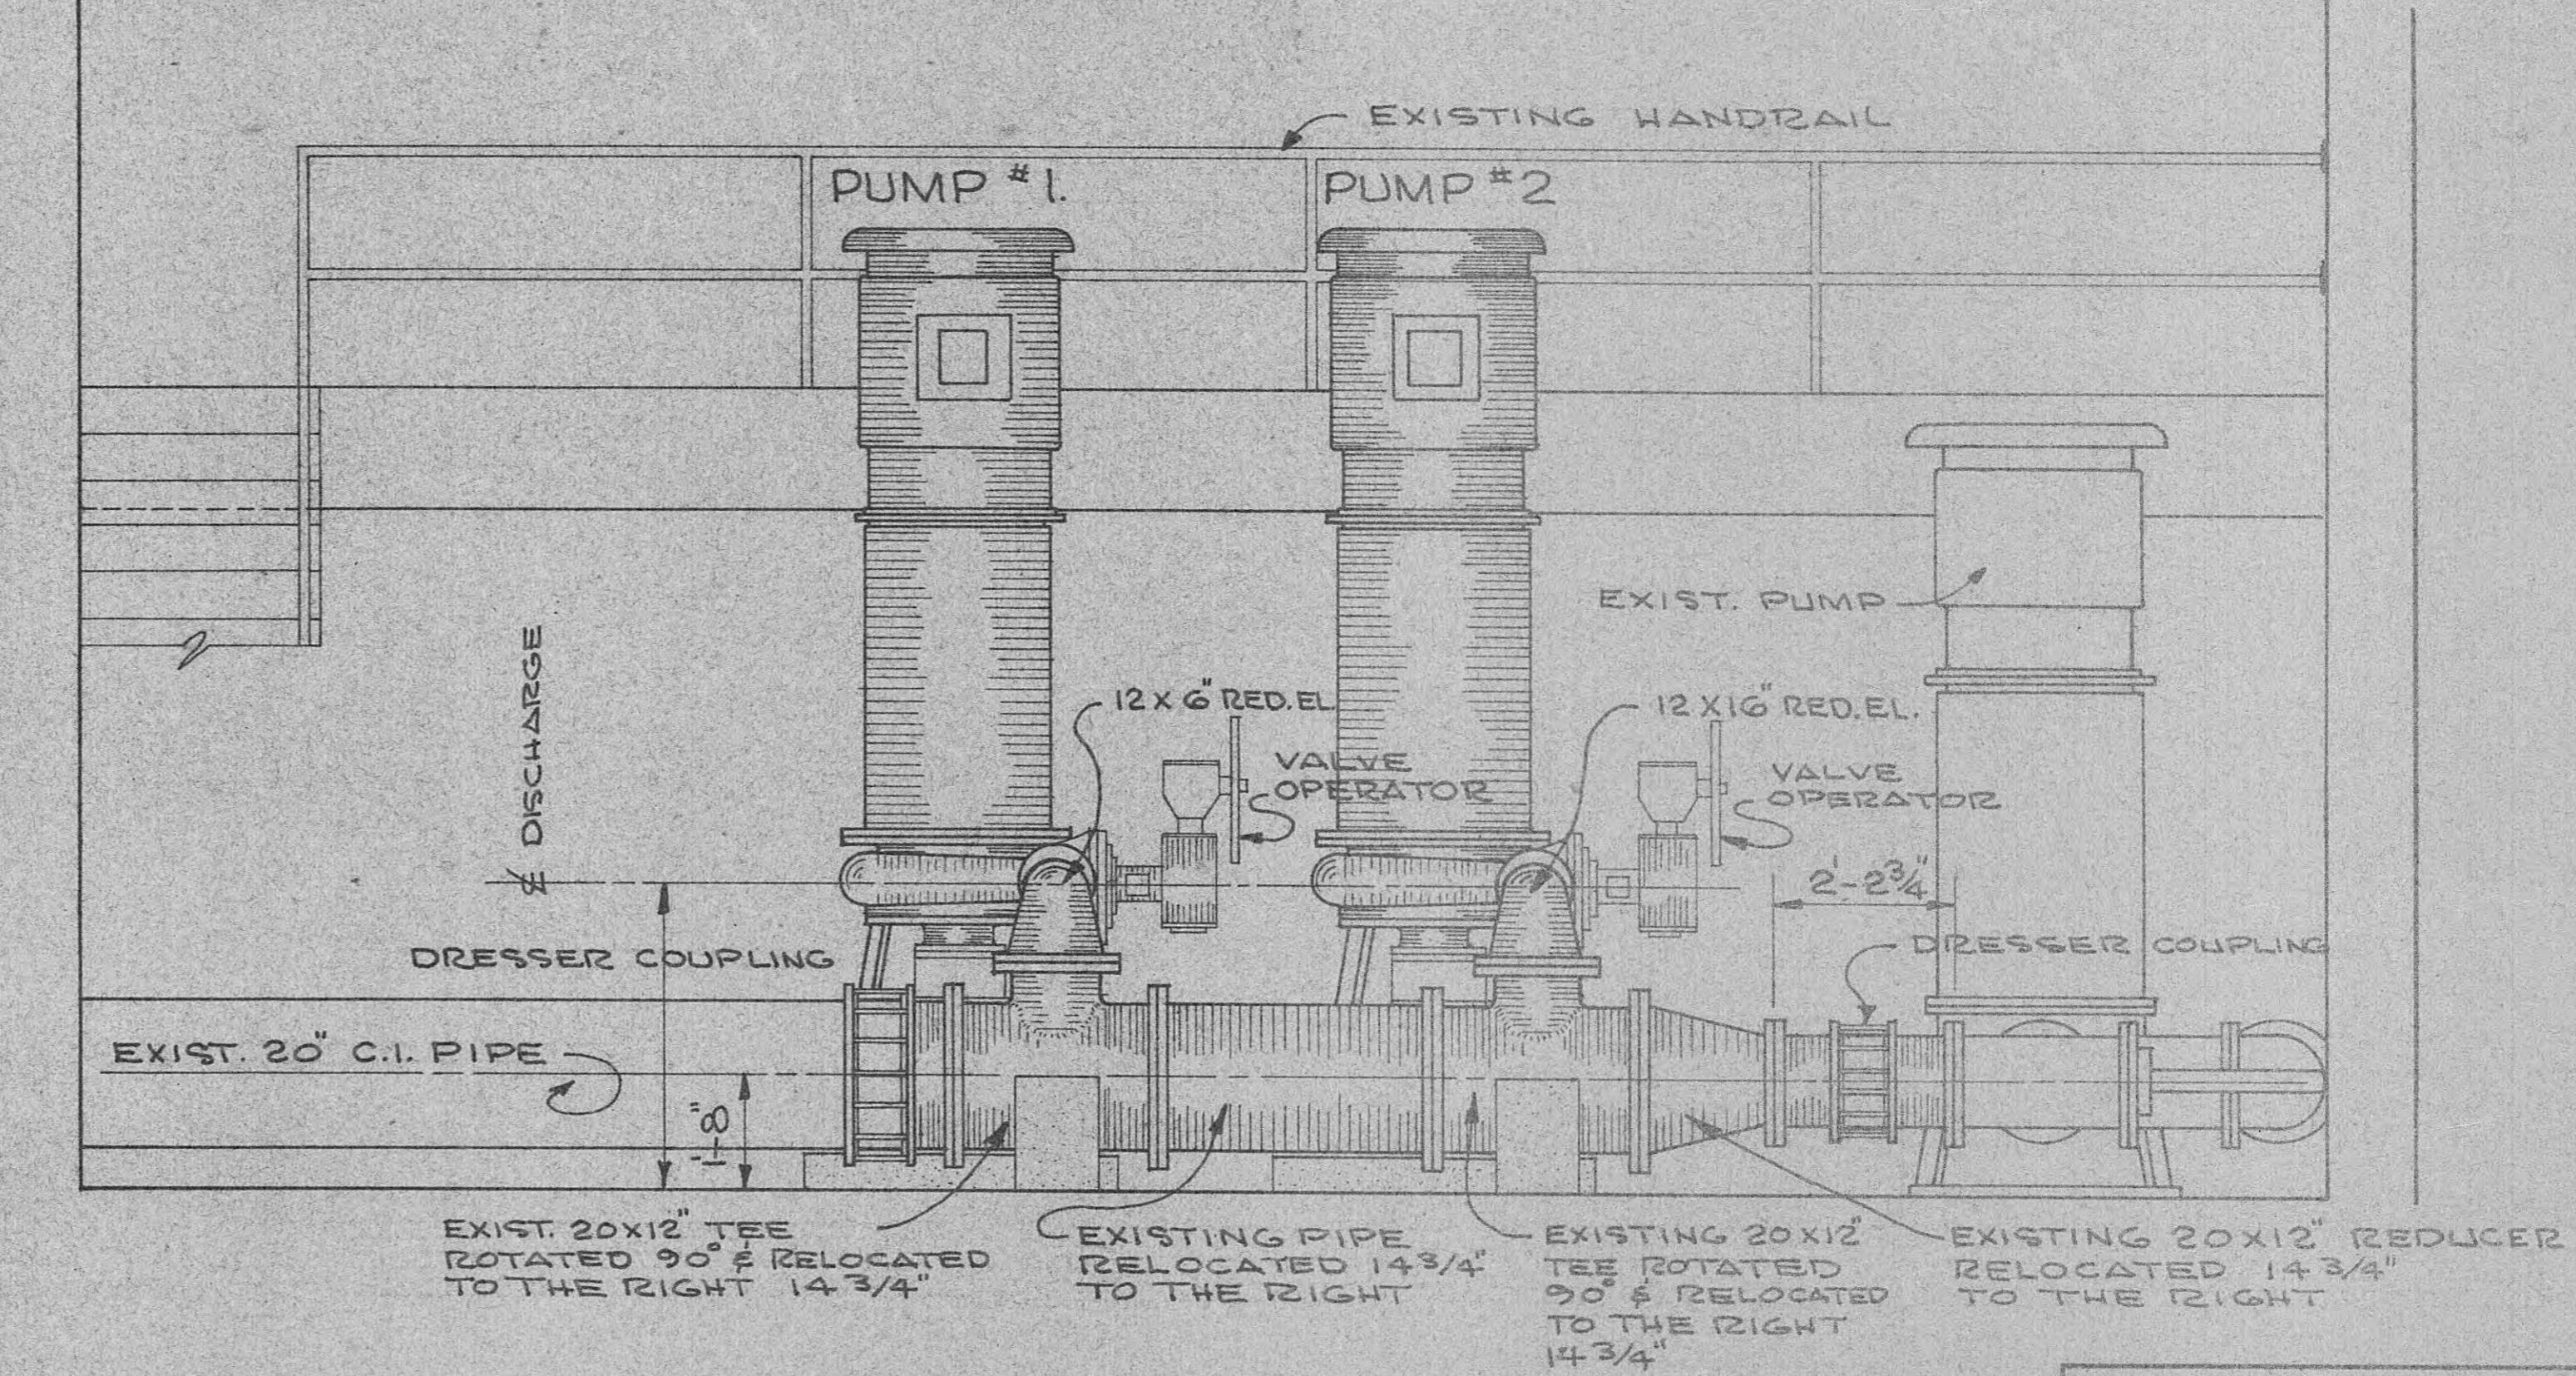

SECTION "B"-B"

SCALE


1/2" = 1'-0"

BLACK, CROW AND EIDSNESS, INC.
ENGINEERS
GAINESVILLE, FLORIDA
DRAWN BY: ROE
CHECKED BY:
SCALE:

DATE:
FILE NO.:


NO.	DESCRIPTION	DATE
	REVISIONS	

SHEET NO.

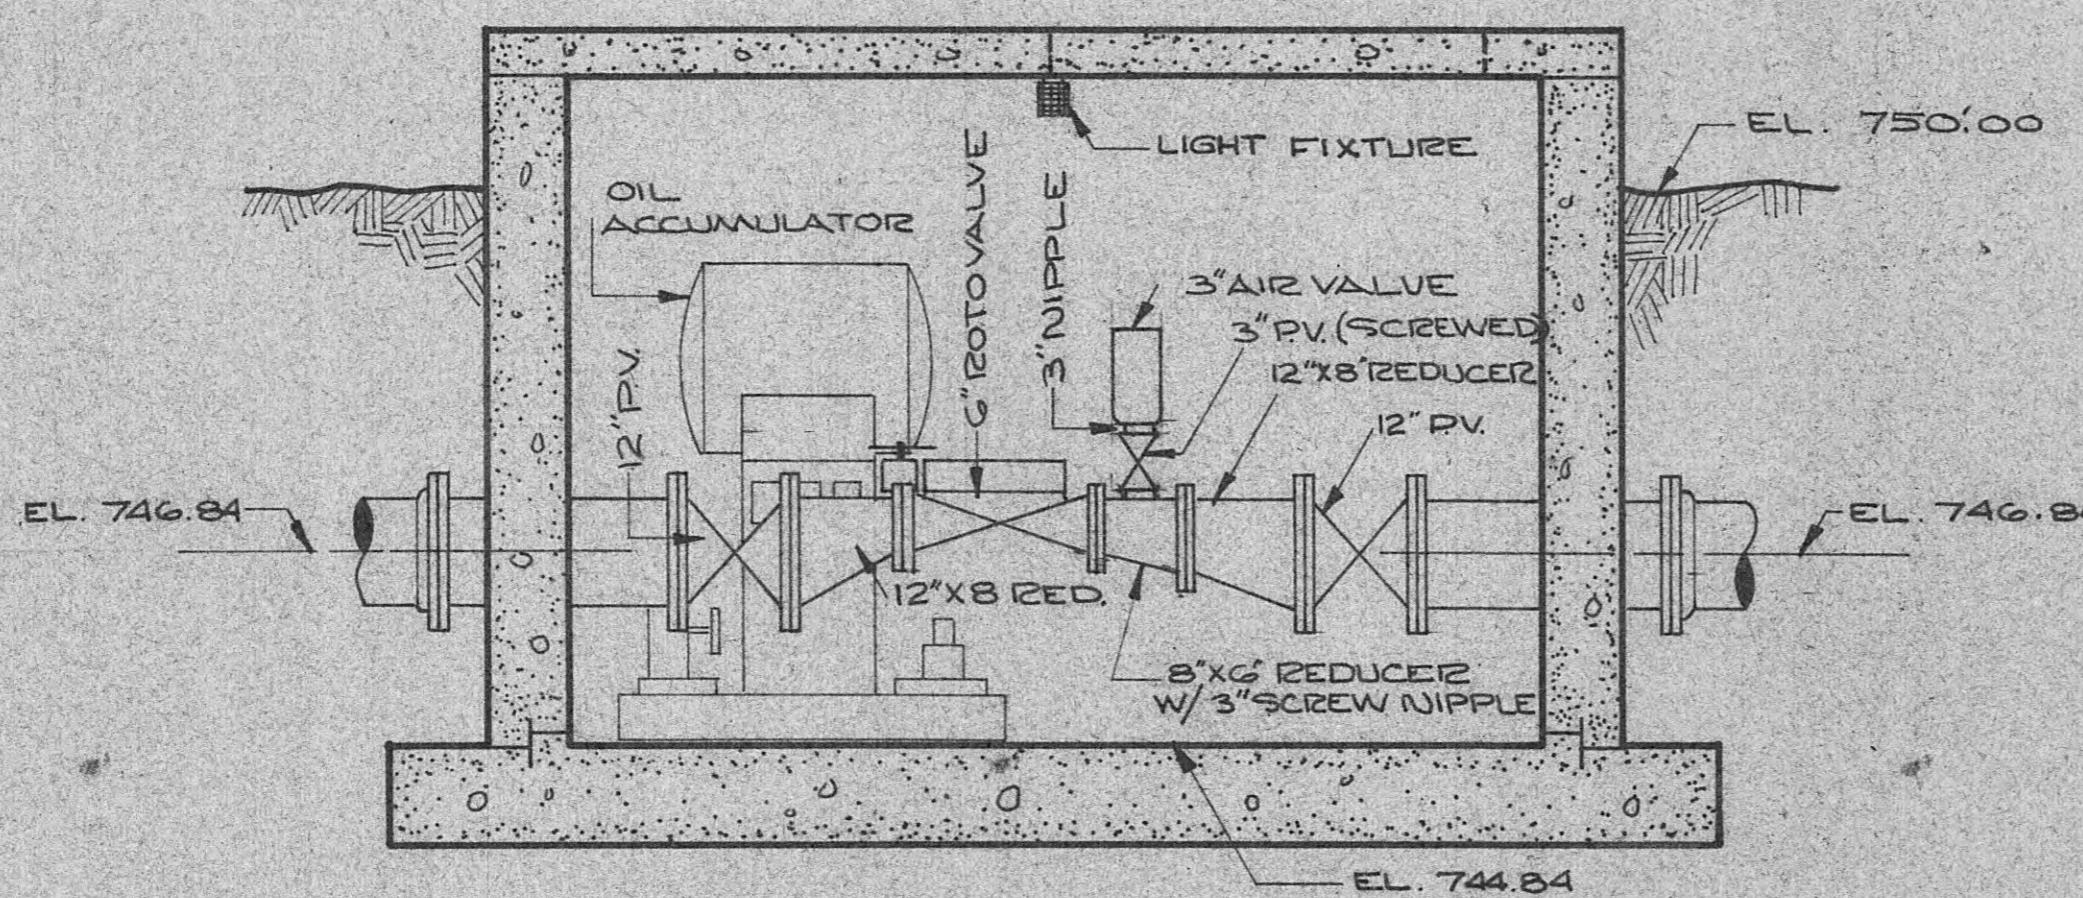


SECTION "A-A"

SCALE $\frac{1}{2}'' = 1'-0''$

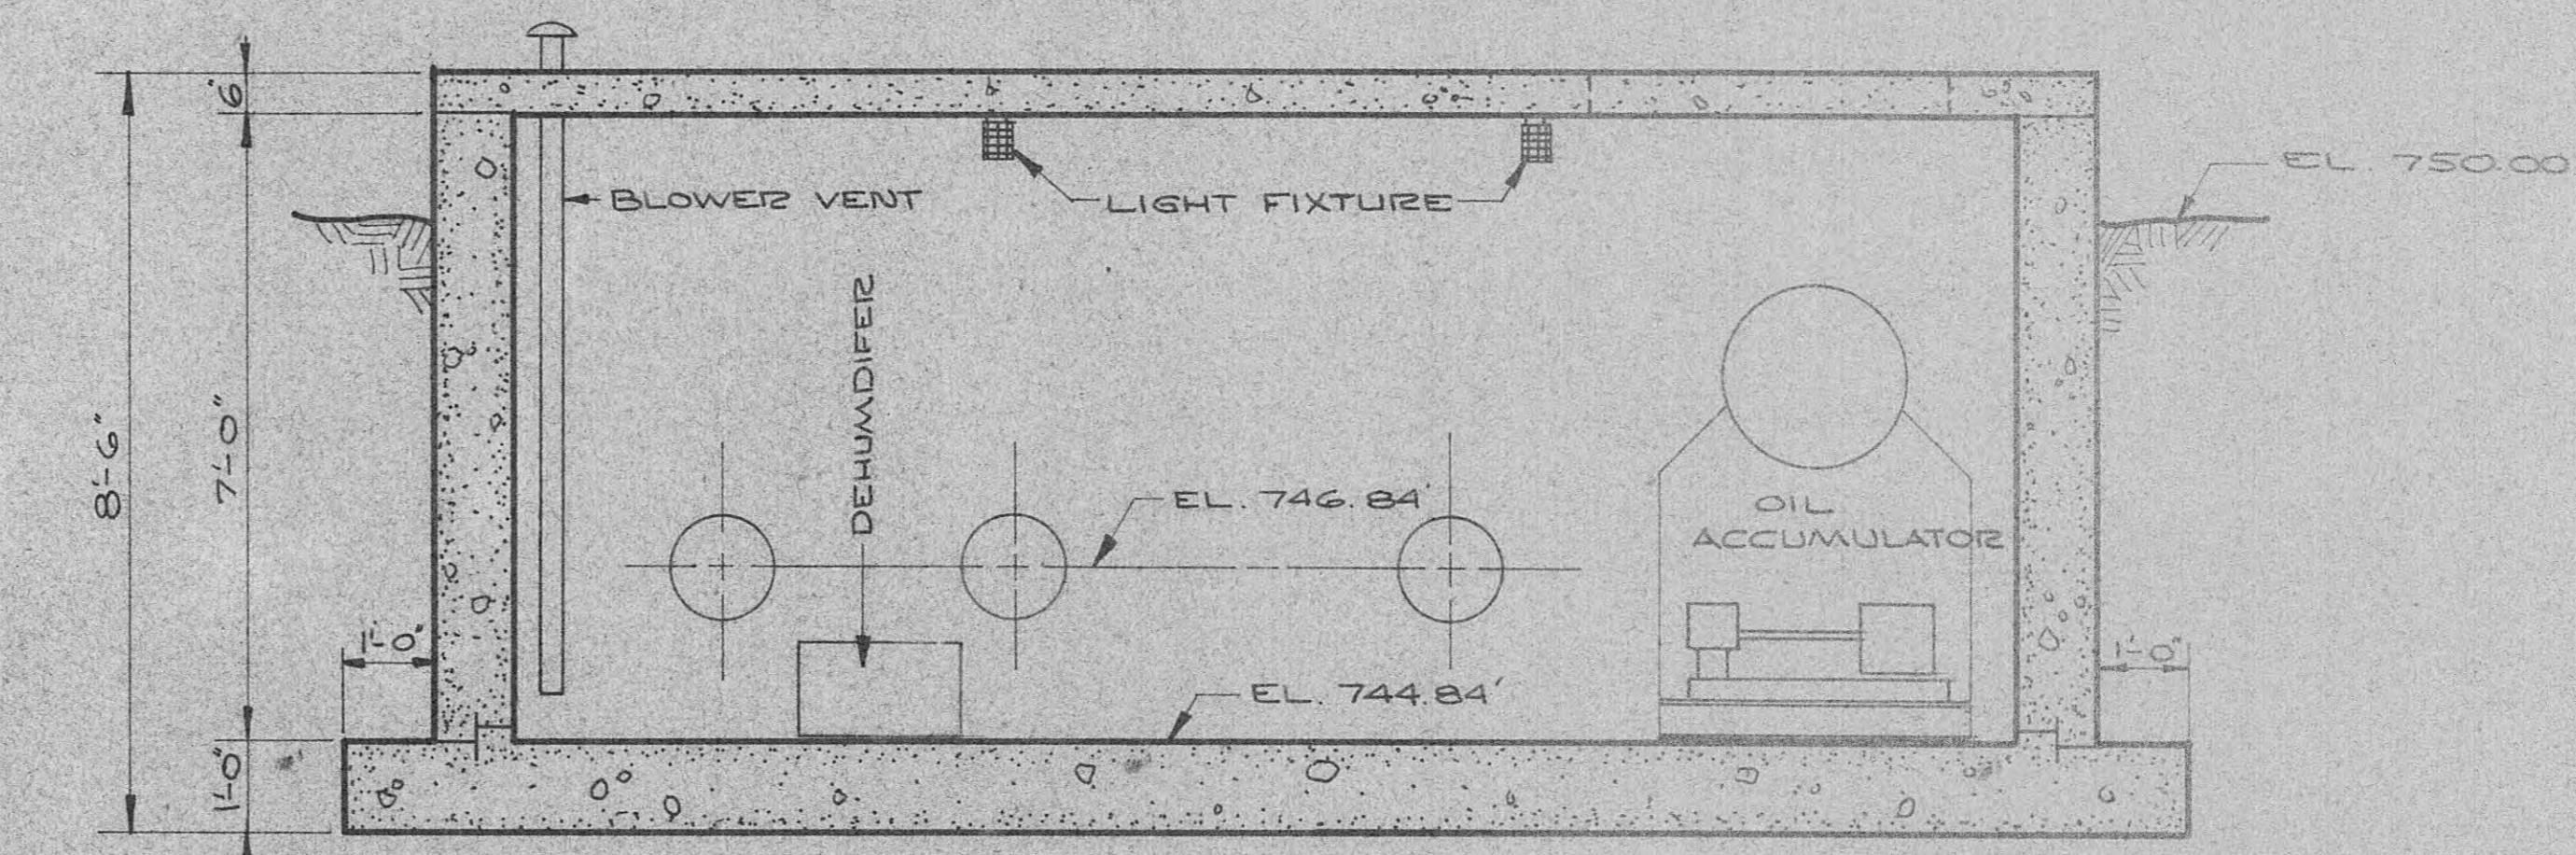


SECTION "B-B"

SCALE $\frac{1}{2}'' = 1'-0''$

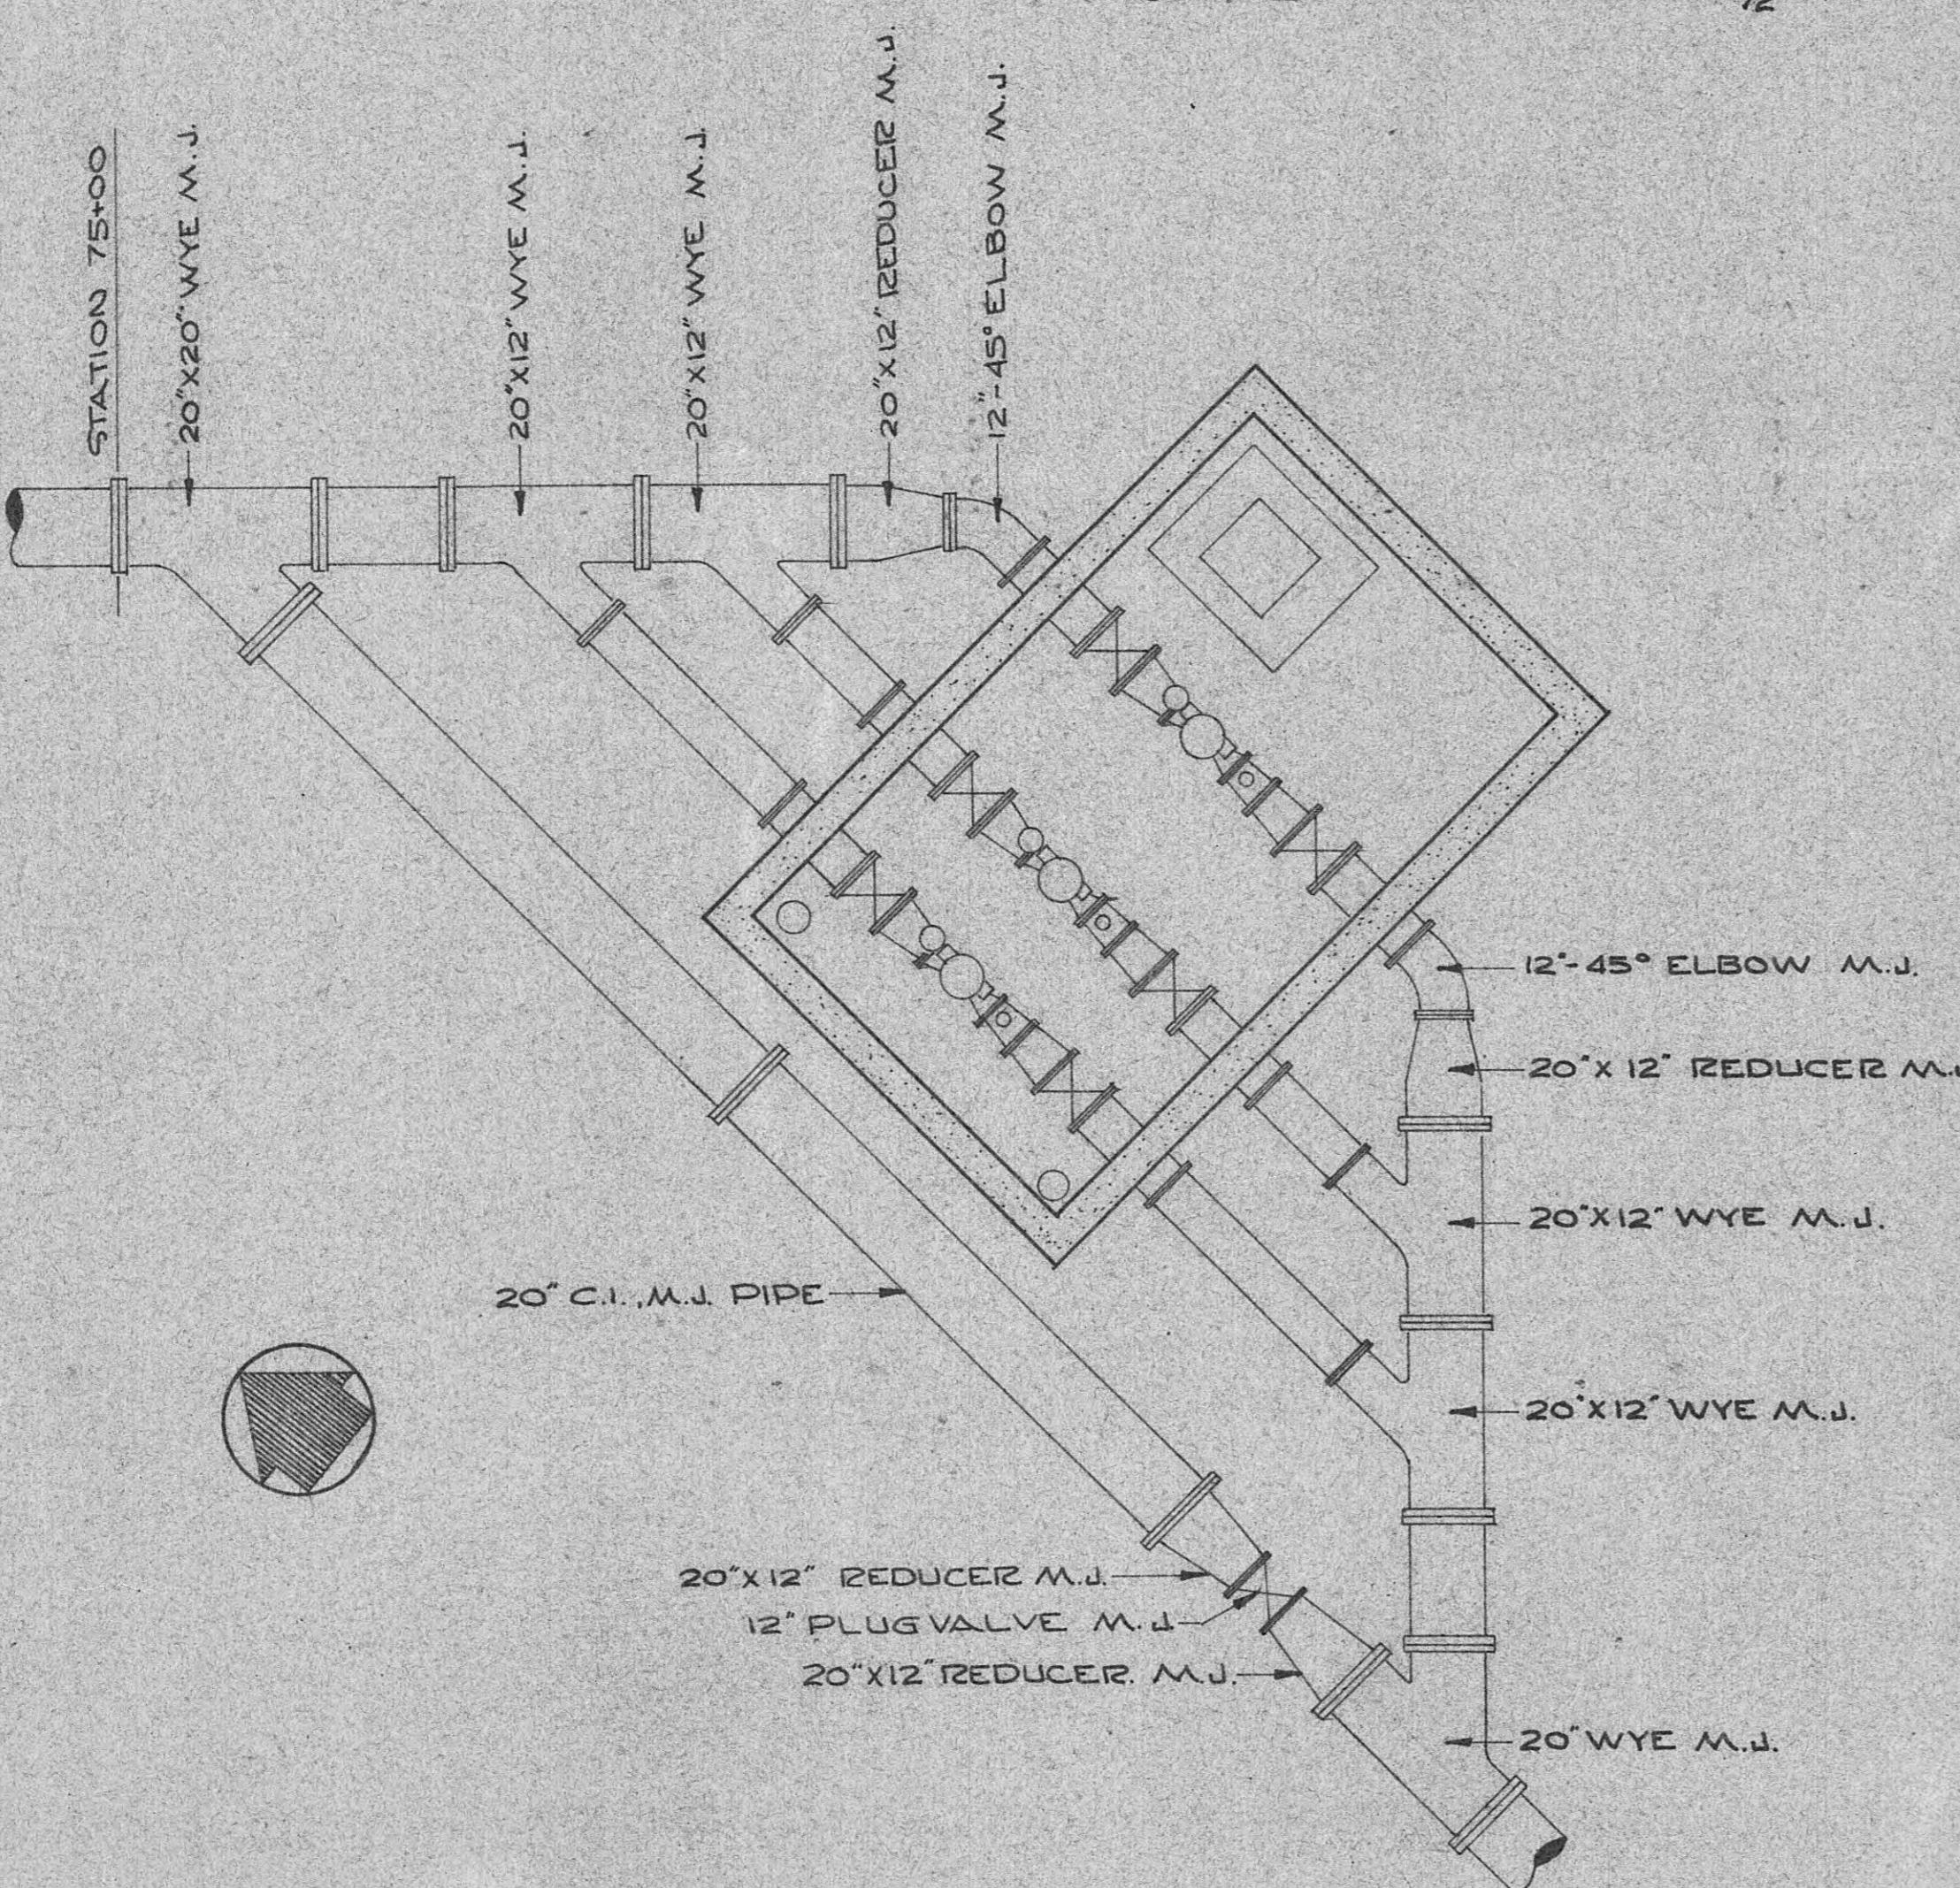

PIPING PLAN

SCALE $\frac{1}{4}'' = 1'-0''$

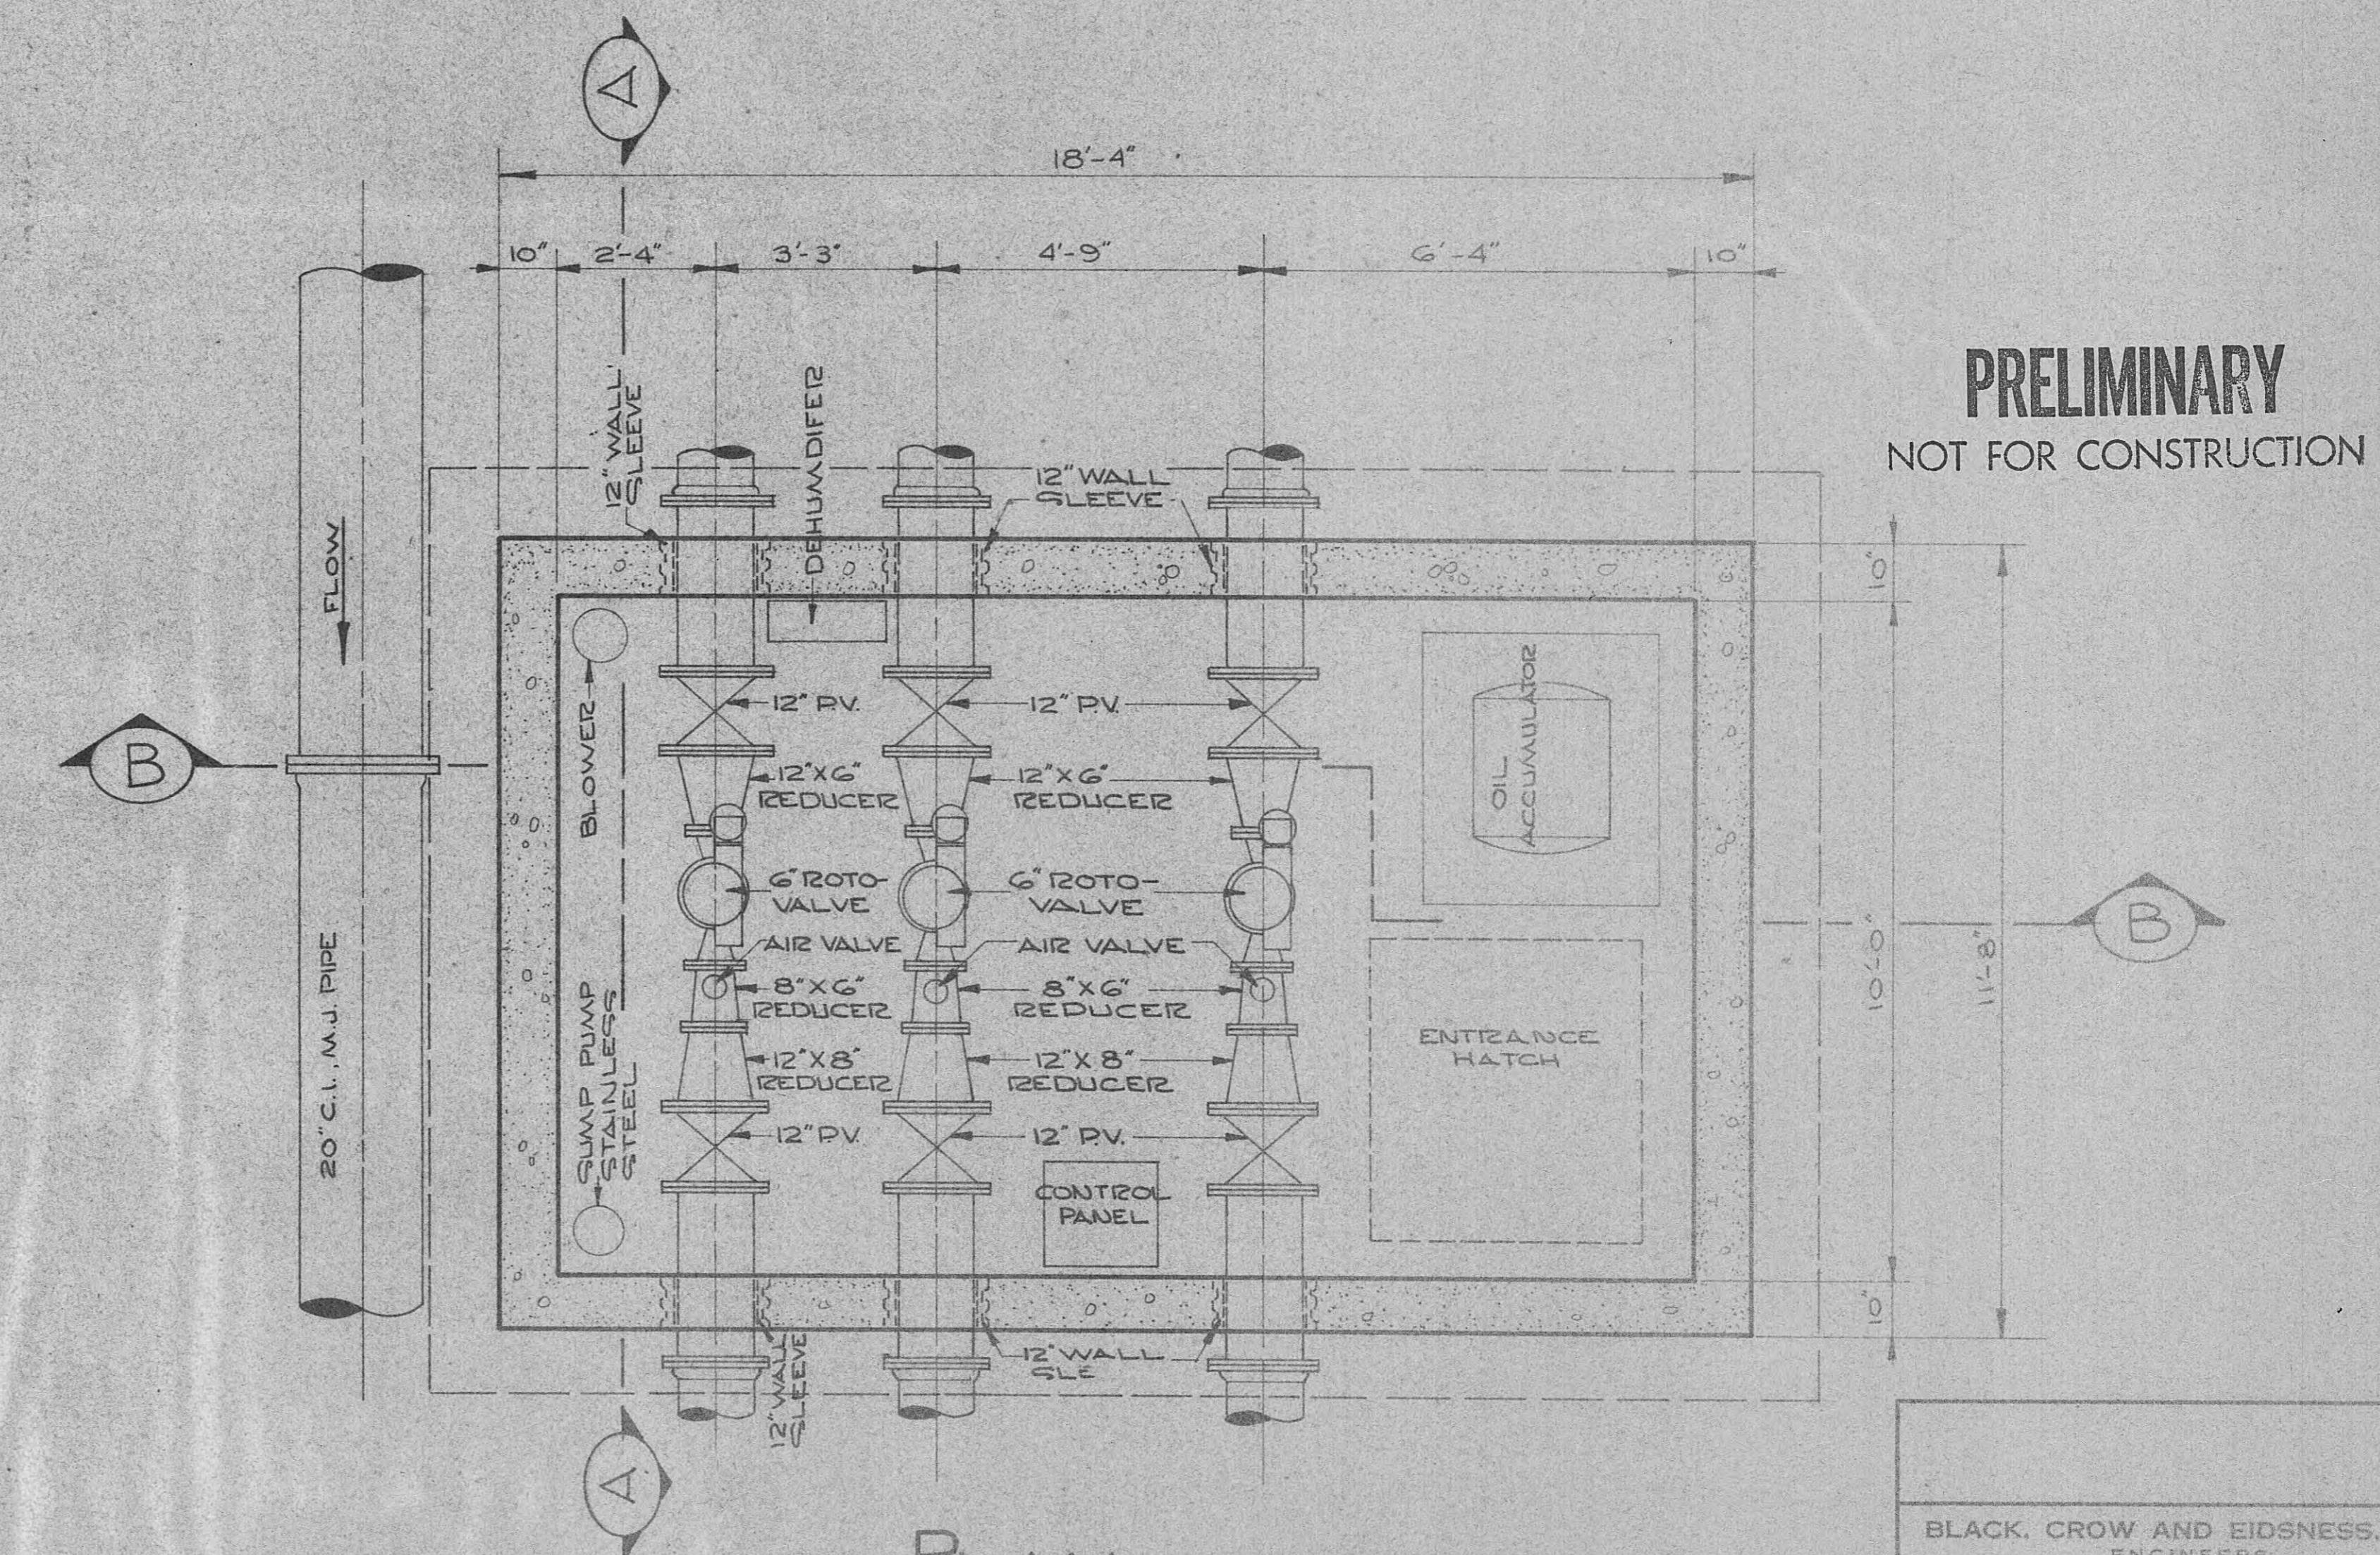

PLAN


SCALE $\frac{1}{2}'' = 1'-0''$

**PRELIMINARY
NOT FOR CONSTRUCTION**

BLACK, CROW AND EIDSNESS, INC.
ENGINEERS
GAINESVILLE, FLORIDA


DRAWN BY: L.G.E. DATE:
CHECKED BY: FILE NO.:
SCALE:

NO.	DESCRIPTION	DATE
REVISIONS		

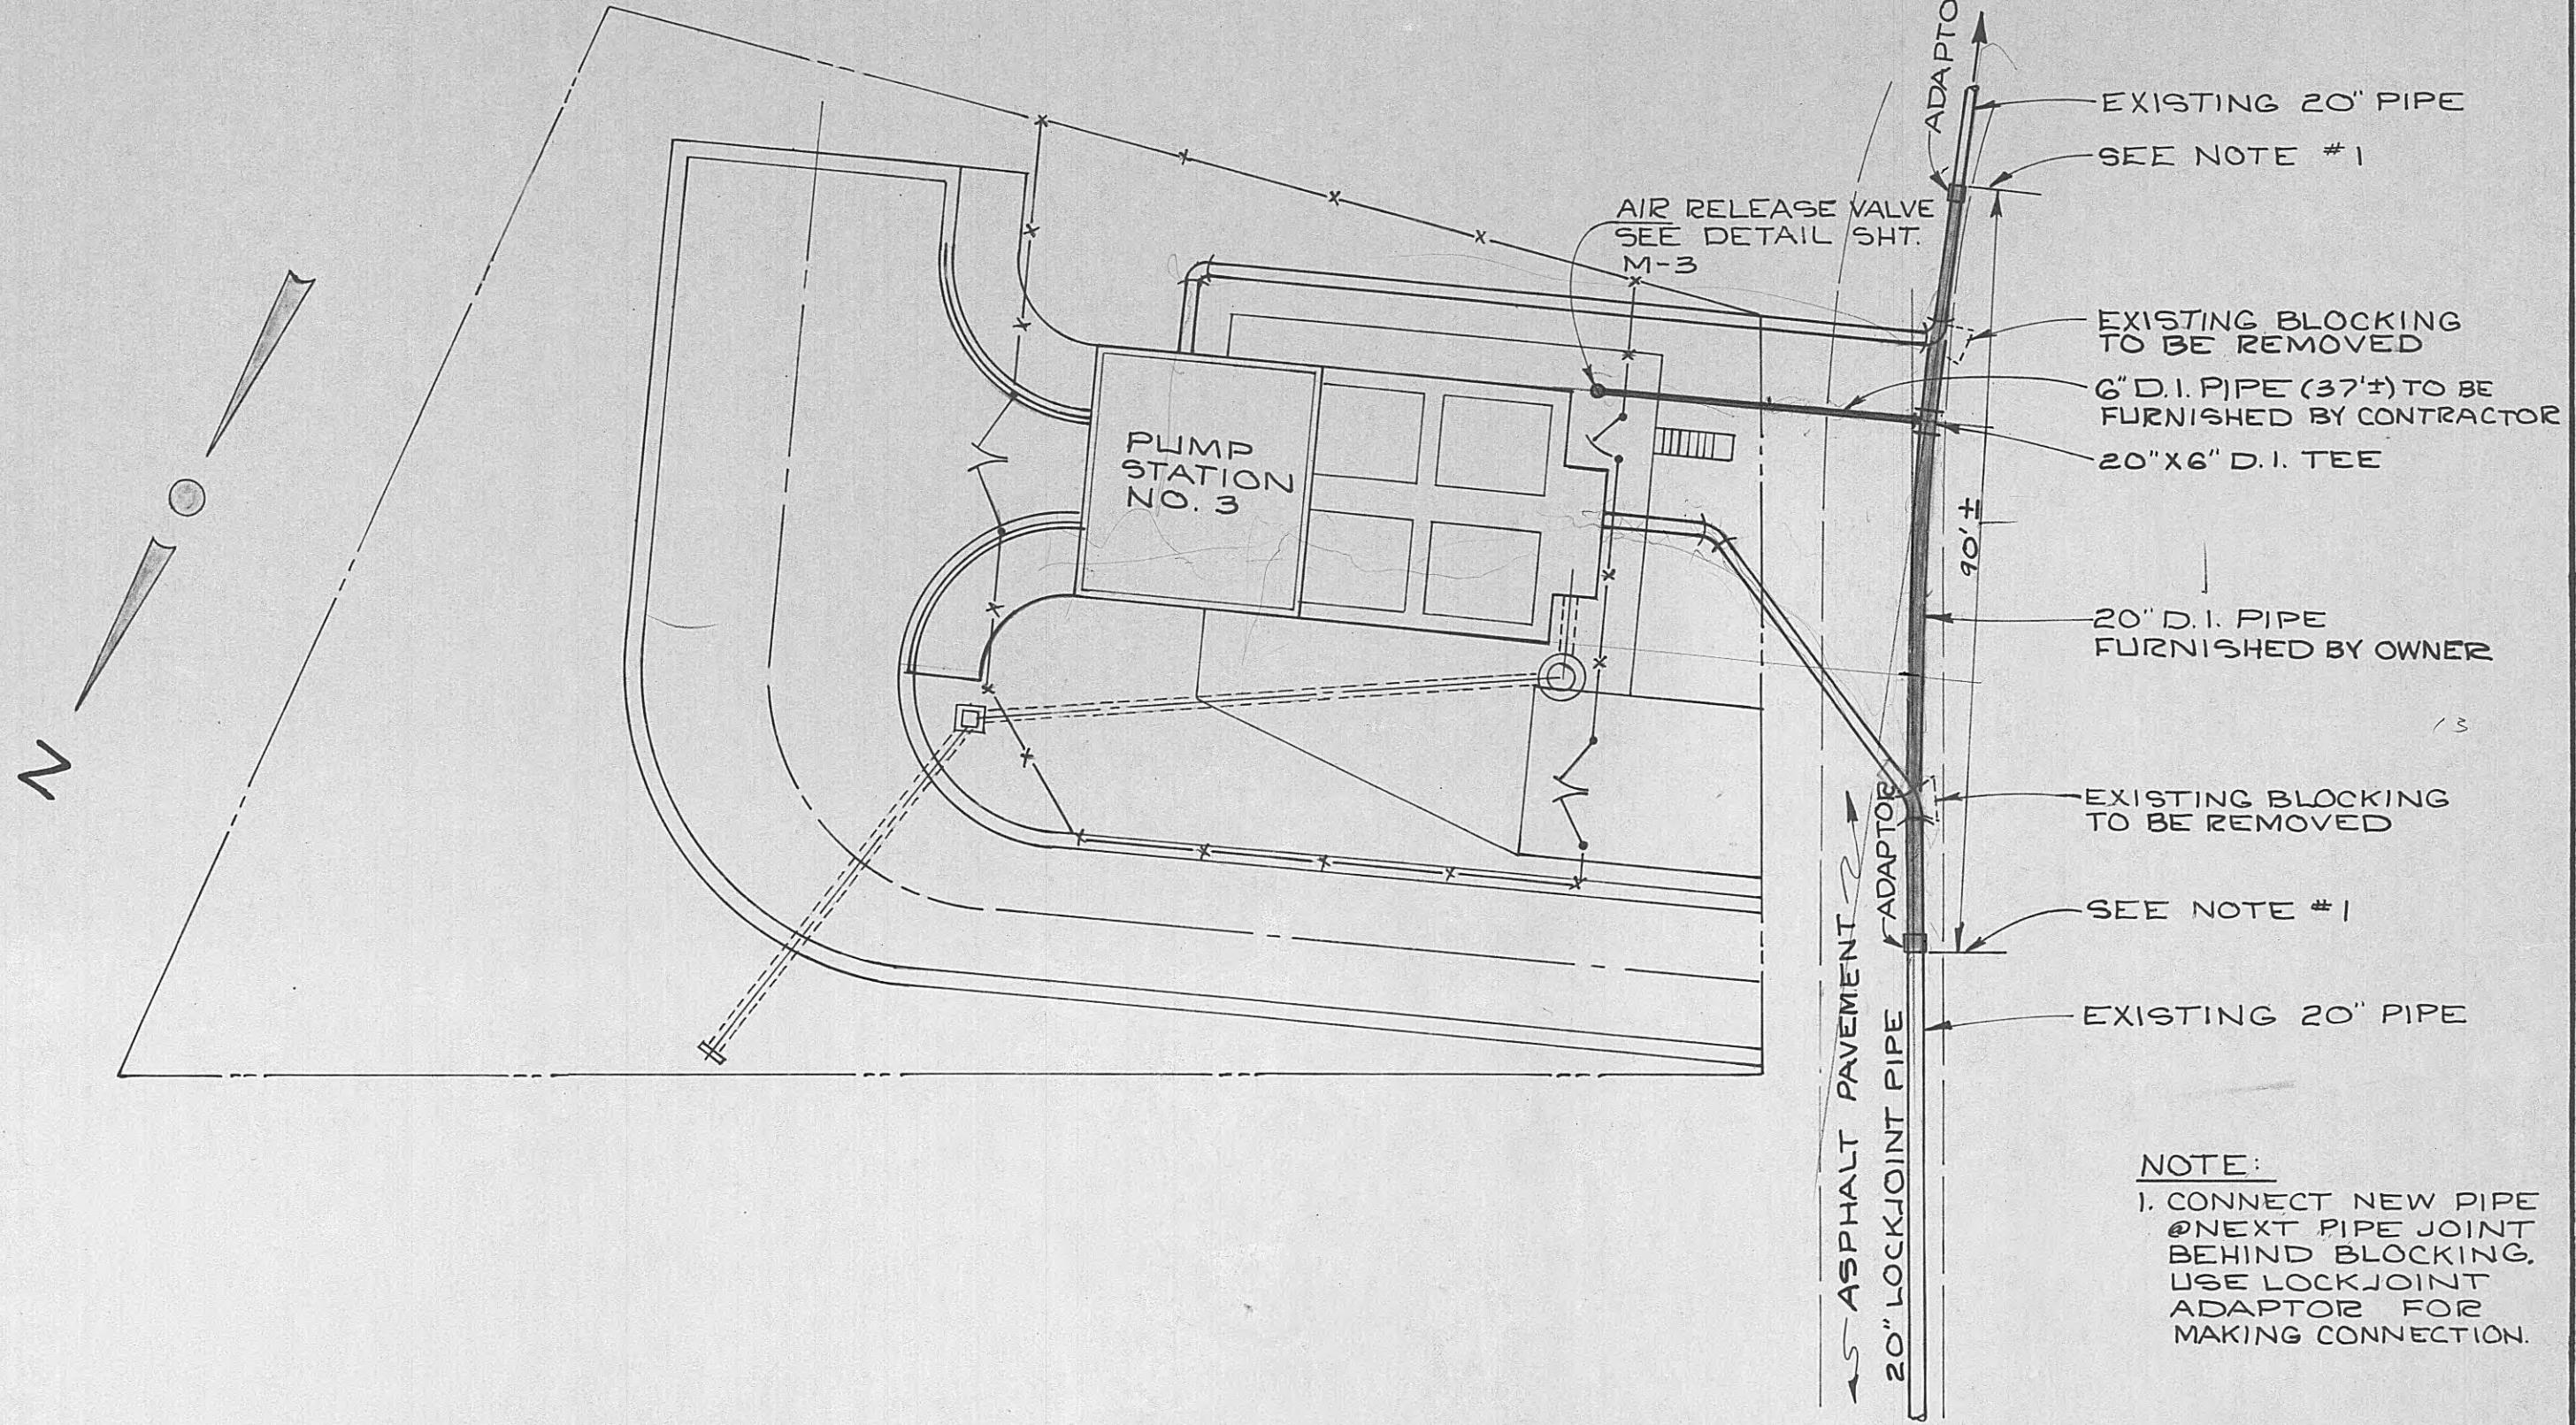

MODIFICATIONS TO PUMP STATION # 3


SCALE 1"-20'-0"

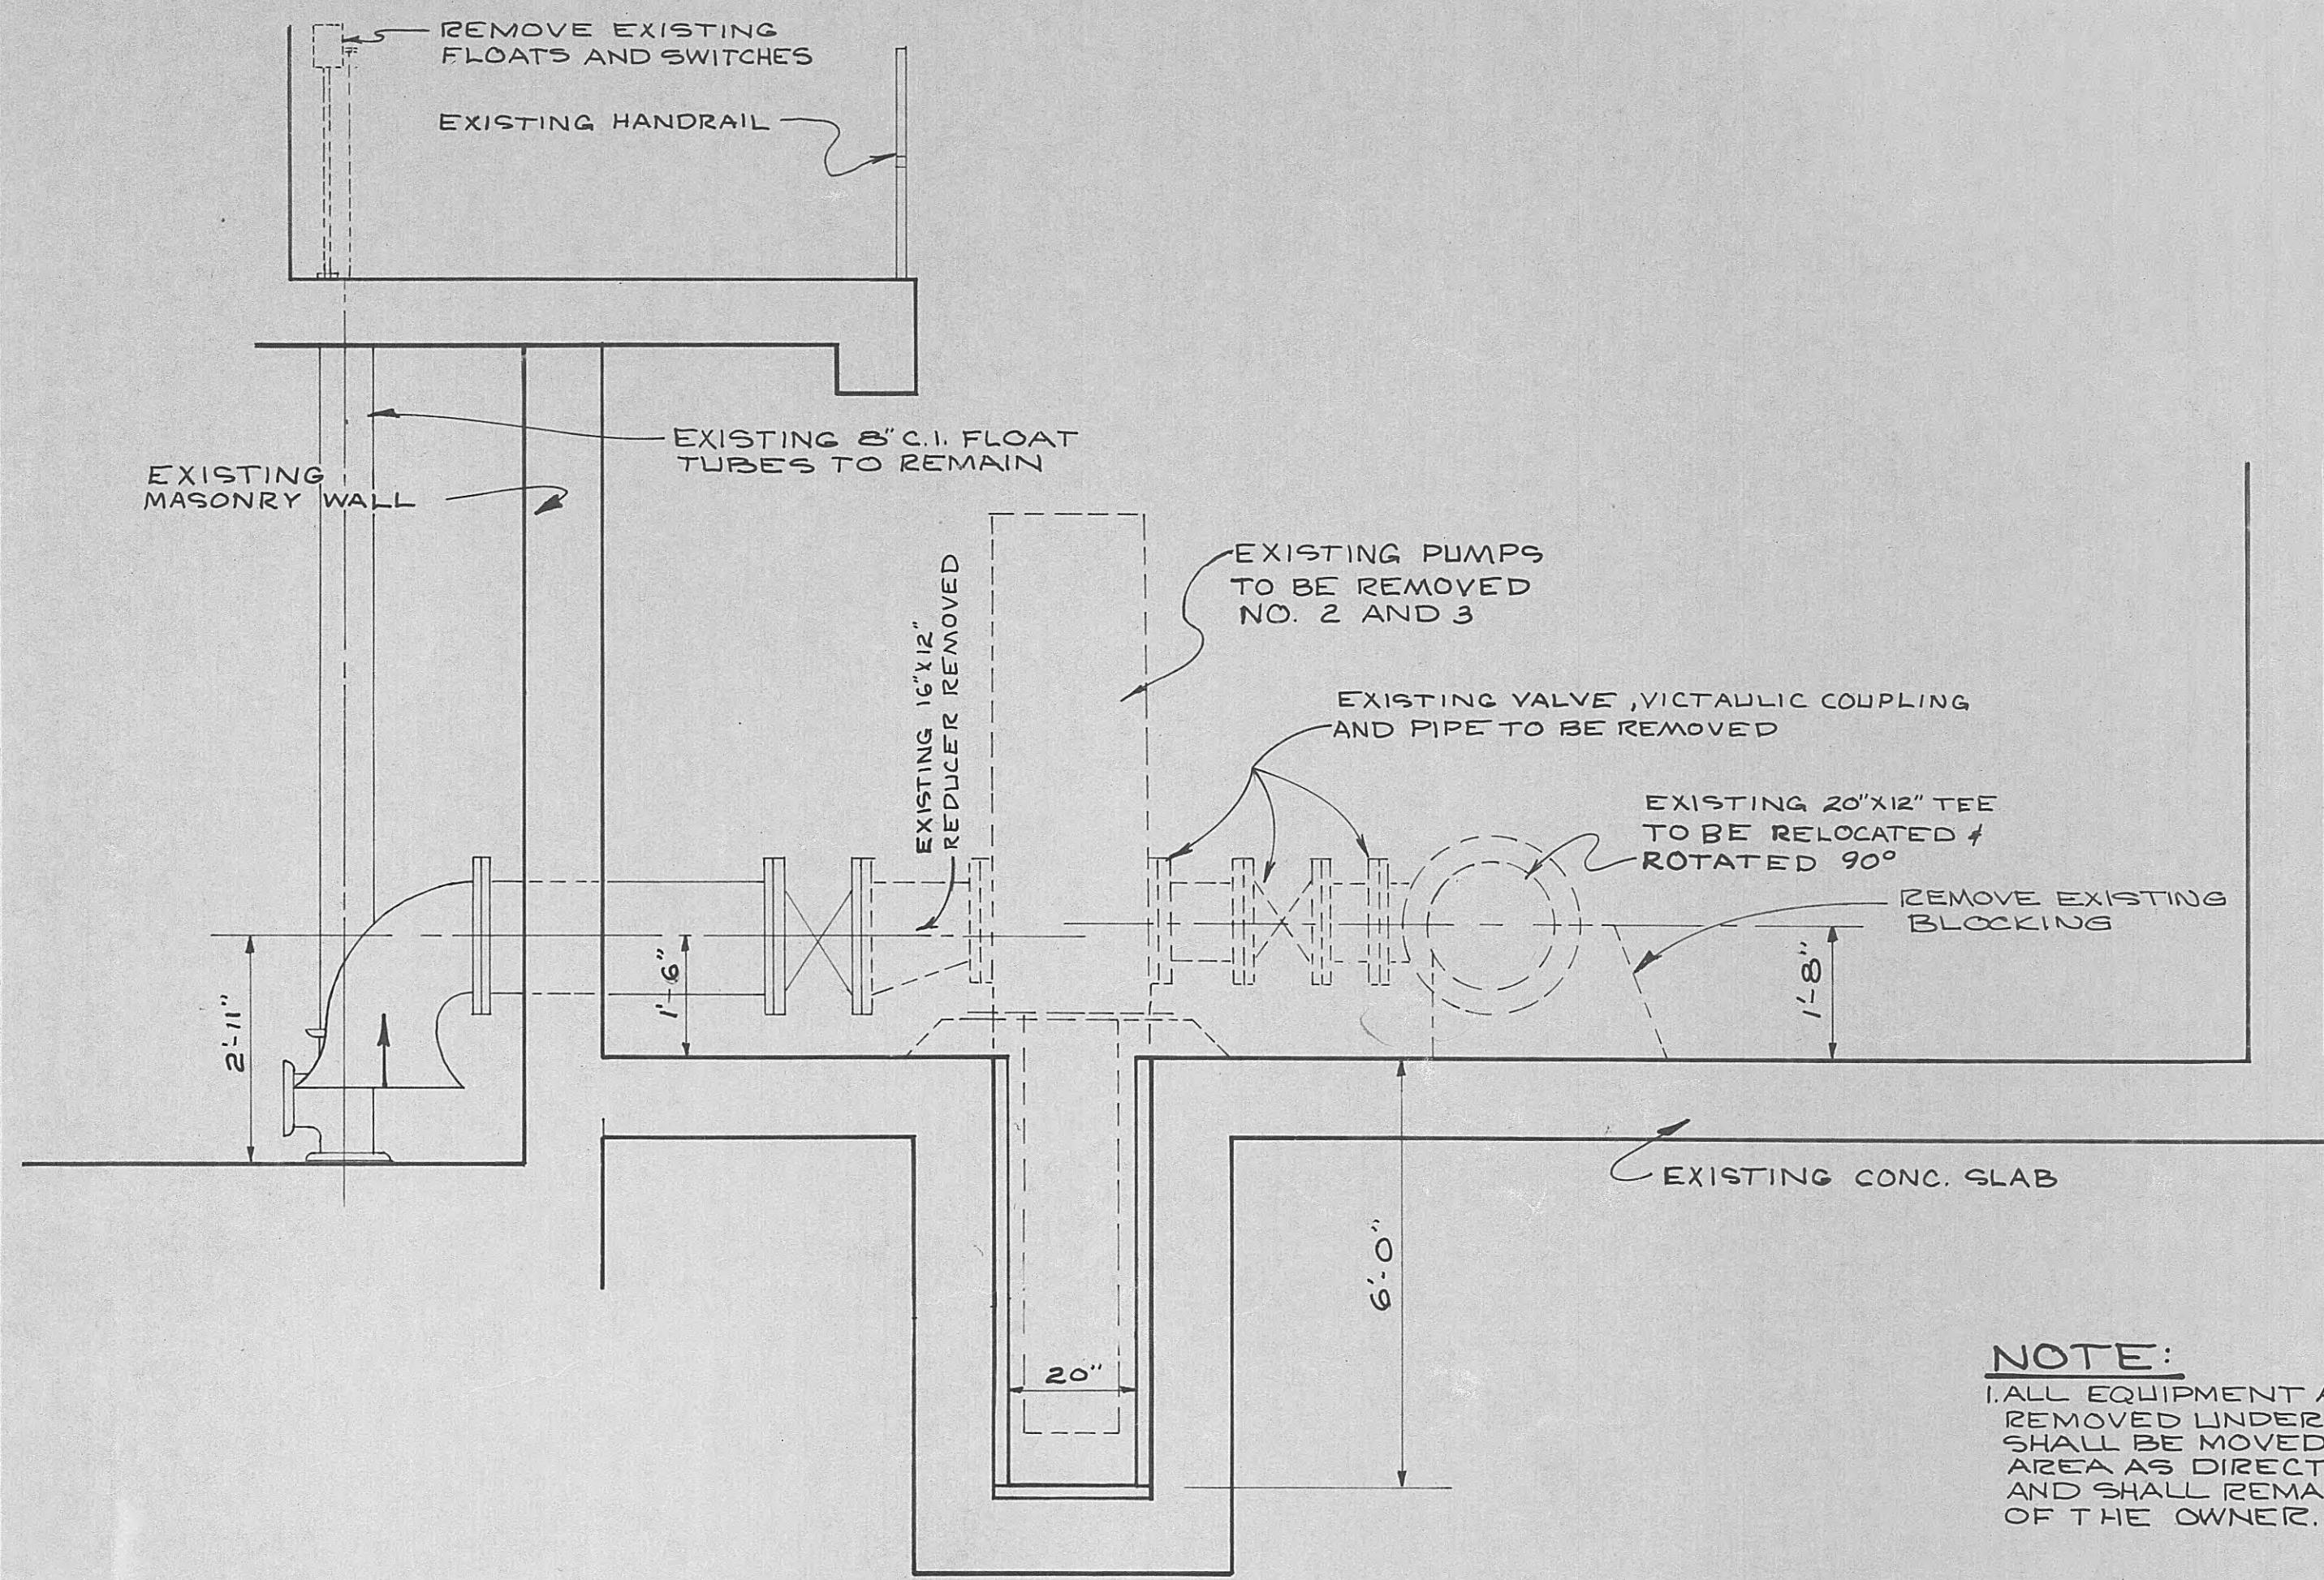

NOTE:
1. ALL EQUIPMENT AND MATERIALS REMOVED UNDER THIS CONTRACT SHALL BE MOVED TO STORAGE AREA AS DIRECTED BY THE OWNER AND SHALL REMAIN IN THE PROPERTY OF THE OWNER.

SECTION A-A

SCALE 1/2"-1'-0"

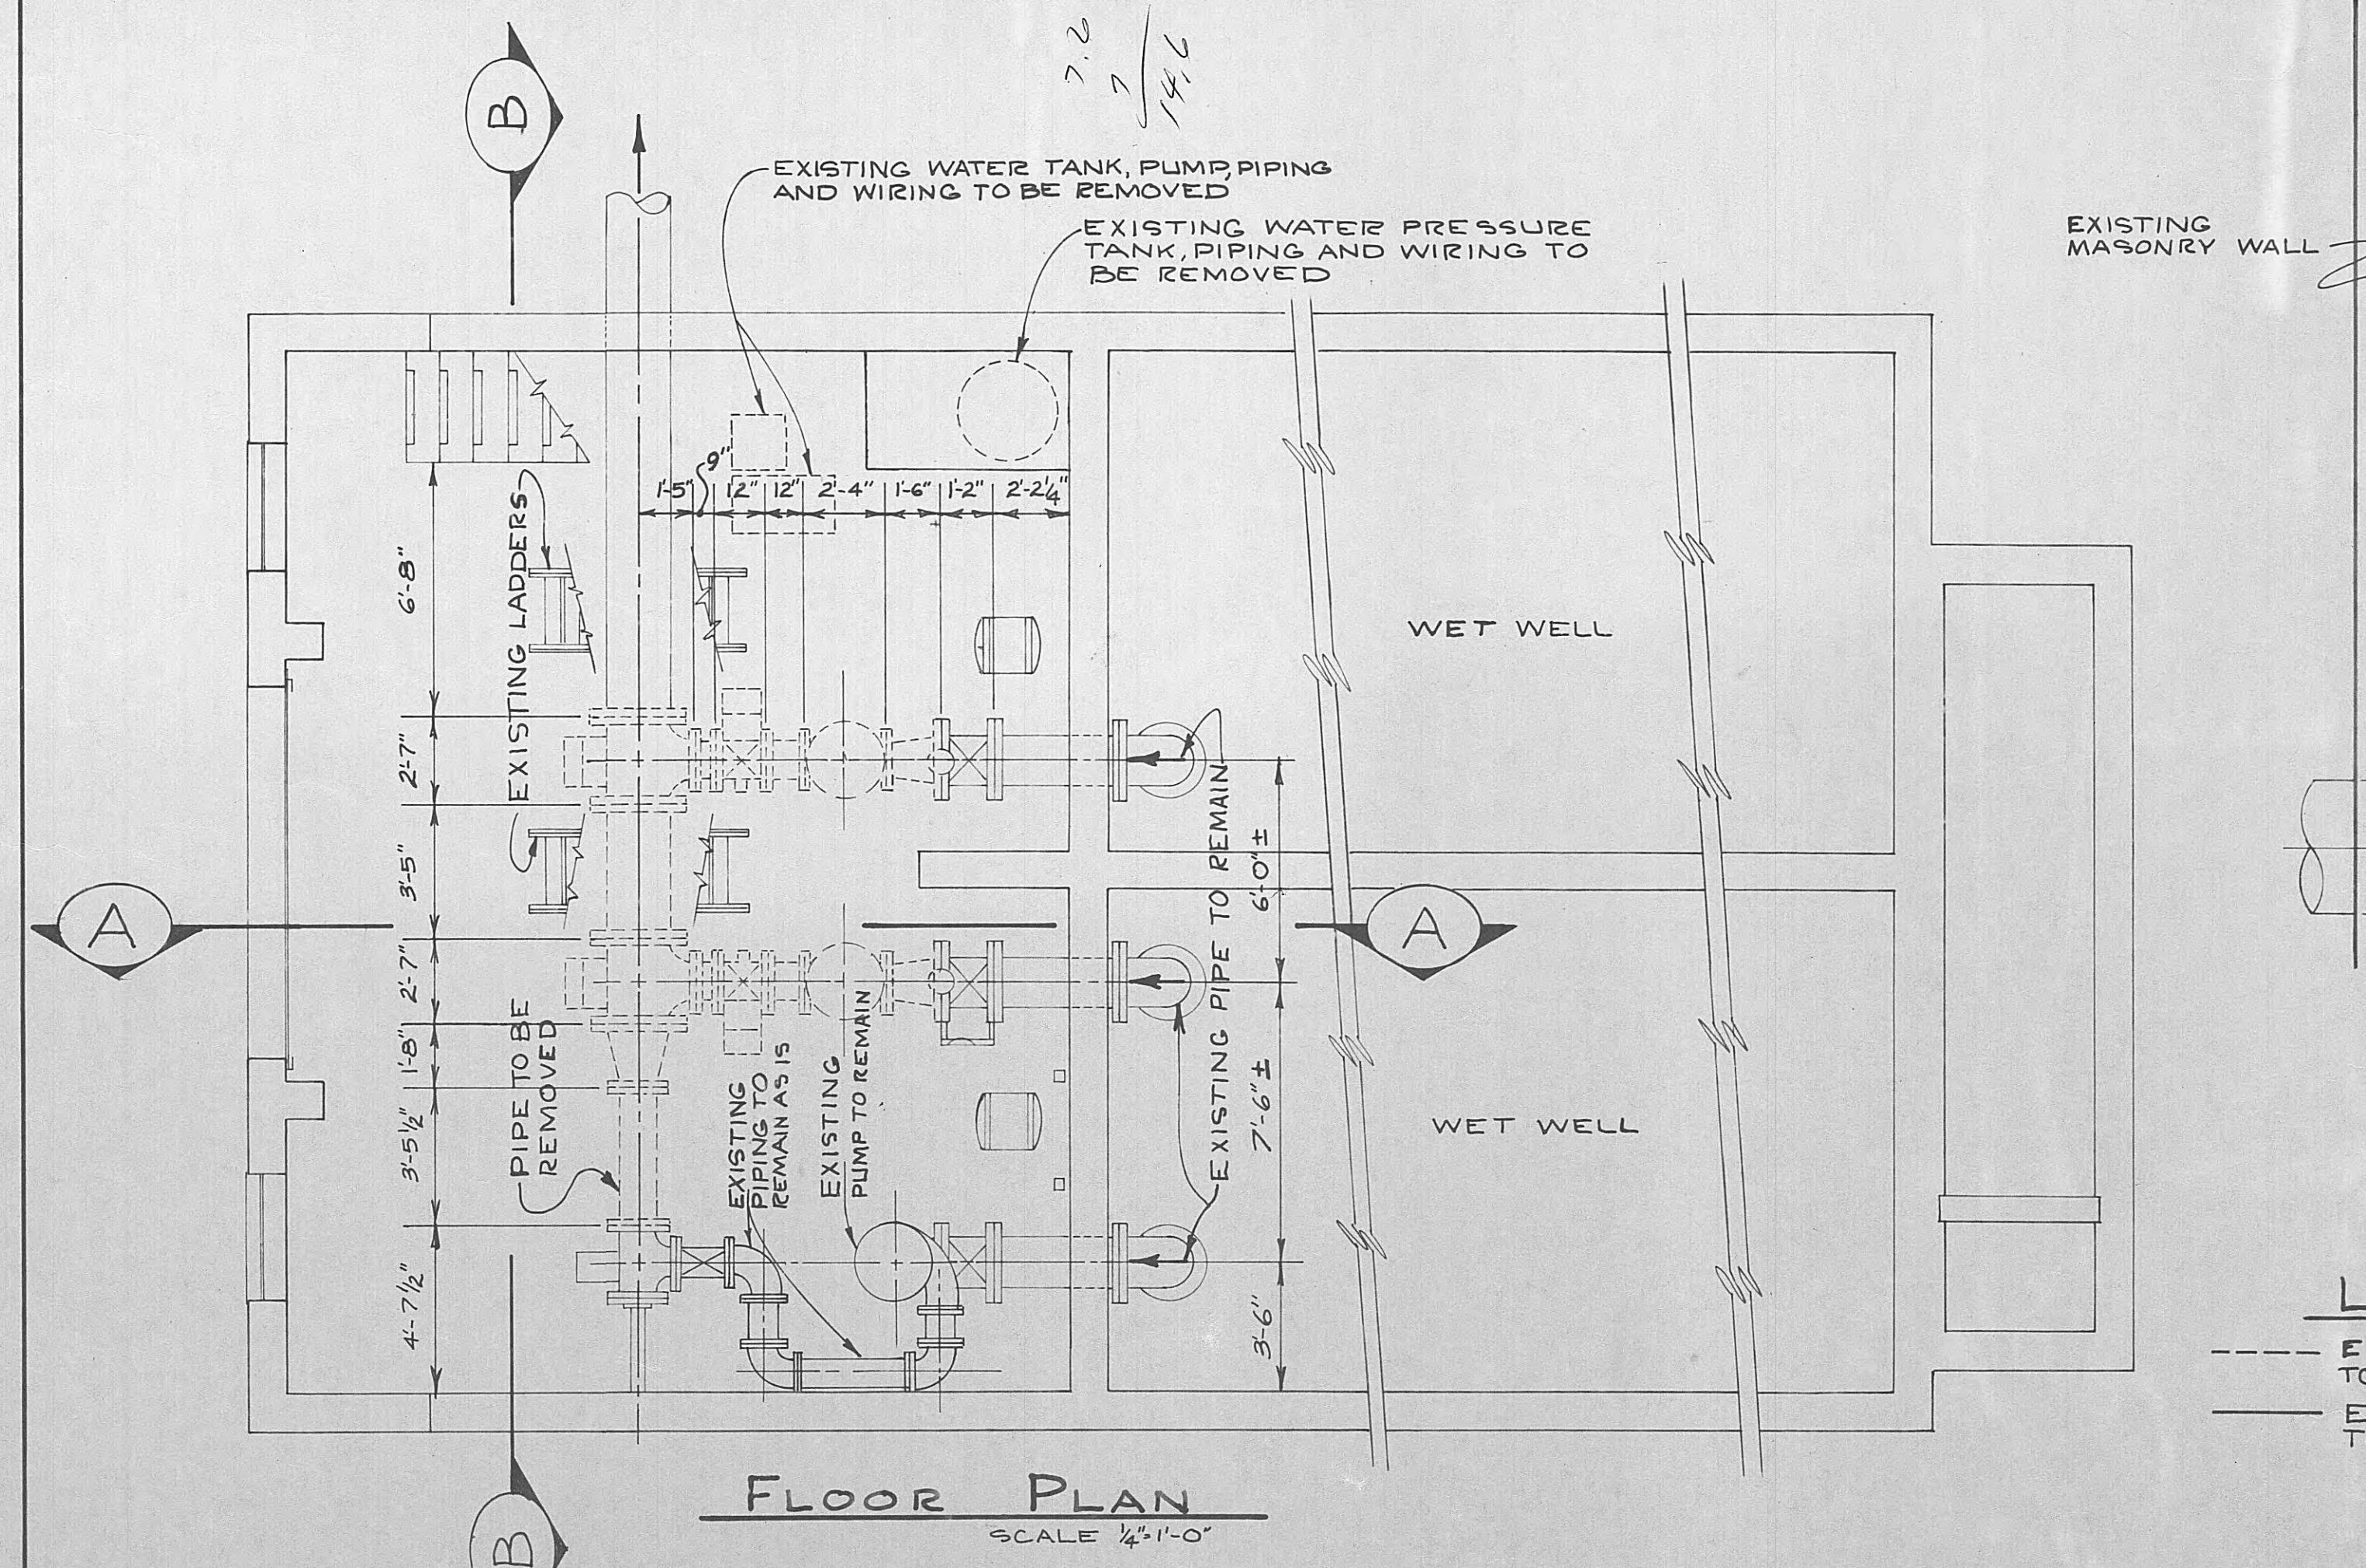

REMOVAL OF EXISTING EQUIPMENT FOR MODIFICATIONS TO EXISTING PUMP STATION # 2

B. K. ELLIOTT CO., P.C. REORDER A-15591

LEGEND


- EXISTING EQUIPMENT TO BE REMOVED
- EXISTING EQUIPMENT TO REMAIN

SECTION B-B

SCALE 1/2"-1'-0"




FOR APPROVAL

PHASE II OF		
MODIFICATIONS TO		
EFFLUENT PUMPING SYSTEM		
FOR CITY OF HARRIMAN TENNESSEE		
ROANE COUNTY		
BLACK, CROW AND EIDNESS, INC.		
ENGINEERS		
GAINESVILLE	FLORIDA	
DRAWN BY: ROE	DATE: JUNE 19, 1968	
CHECKED BY:	FILE NO. 47-682	
SCALE: AS NOTED		
EXISTING EQUIPMENT REMOVAL SHEET NO. M-1		
FOR MODIFICATIONS TO EXISTING PUMP STATION # 2		

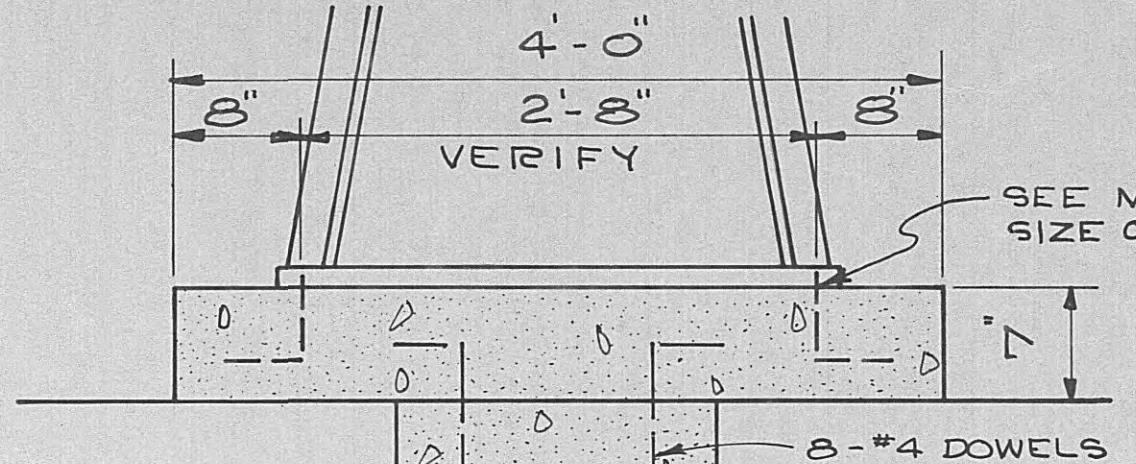

PUMP PAD DETAIL

SCALE 1" = 1'-0"

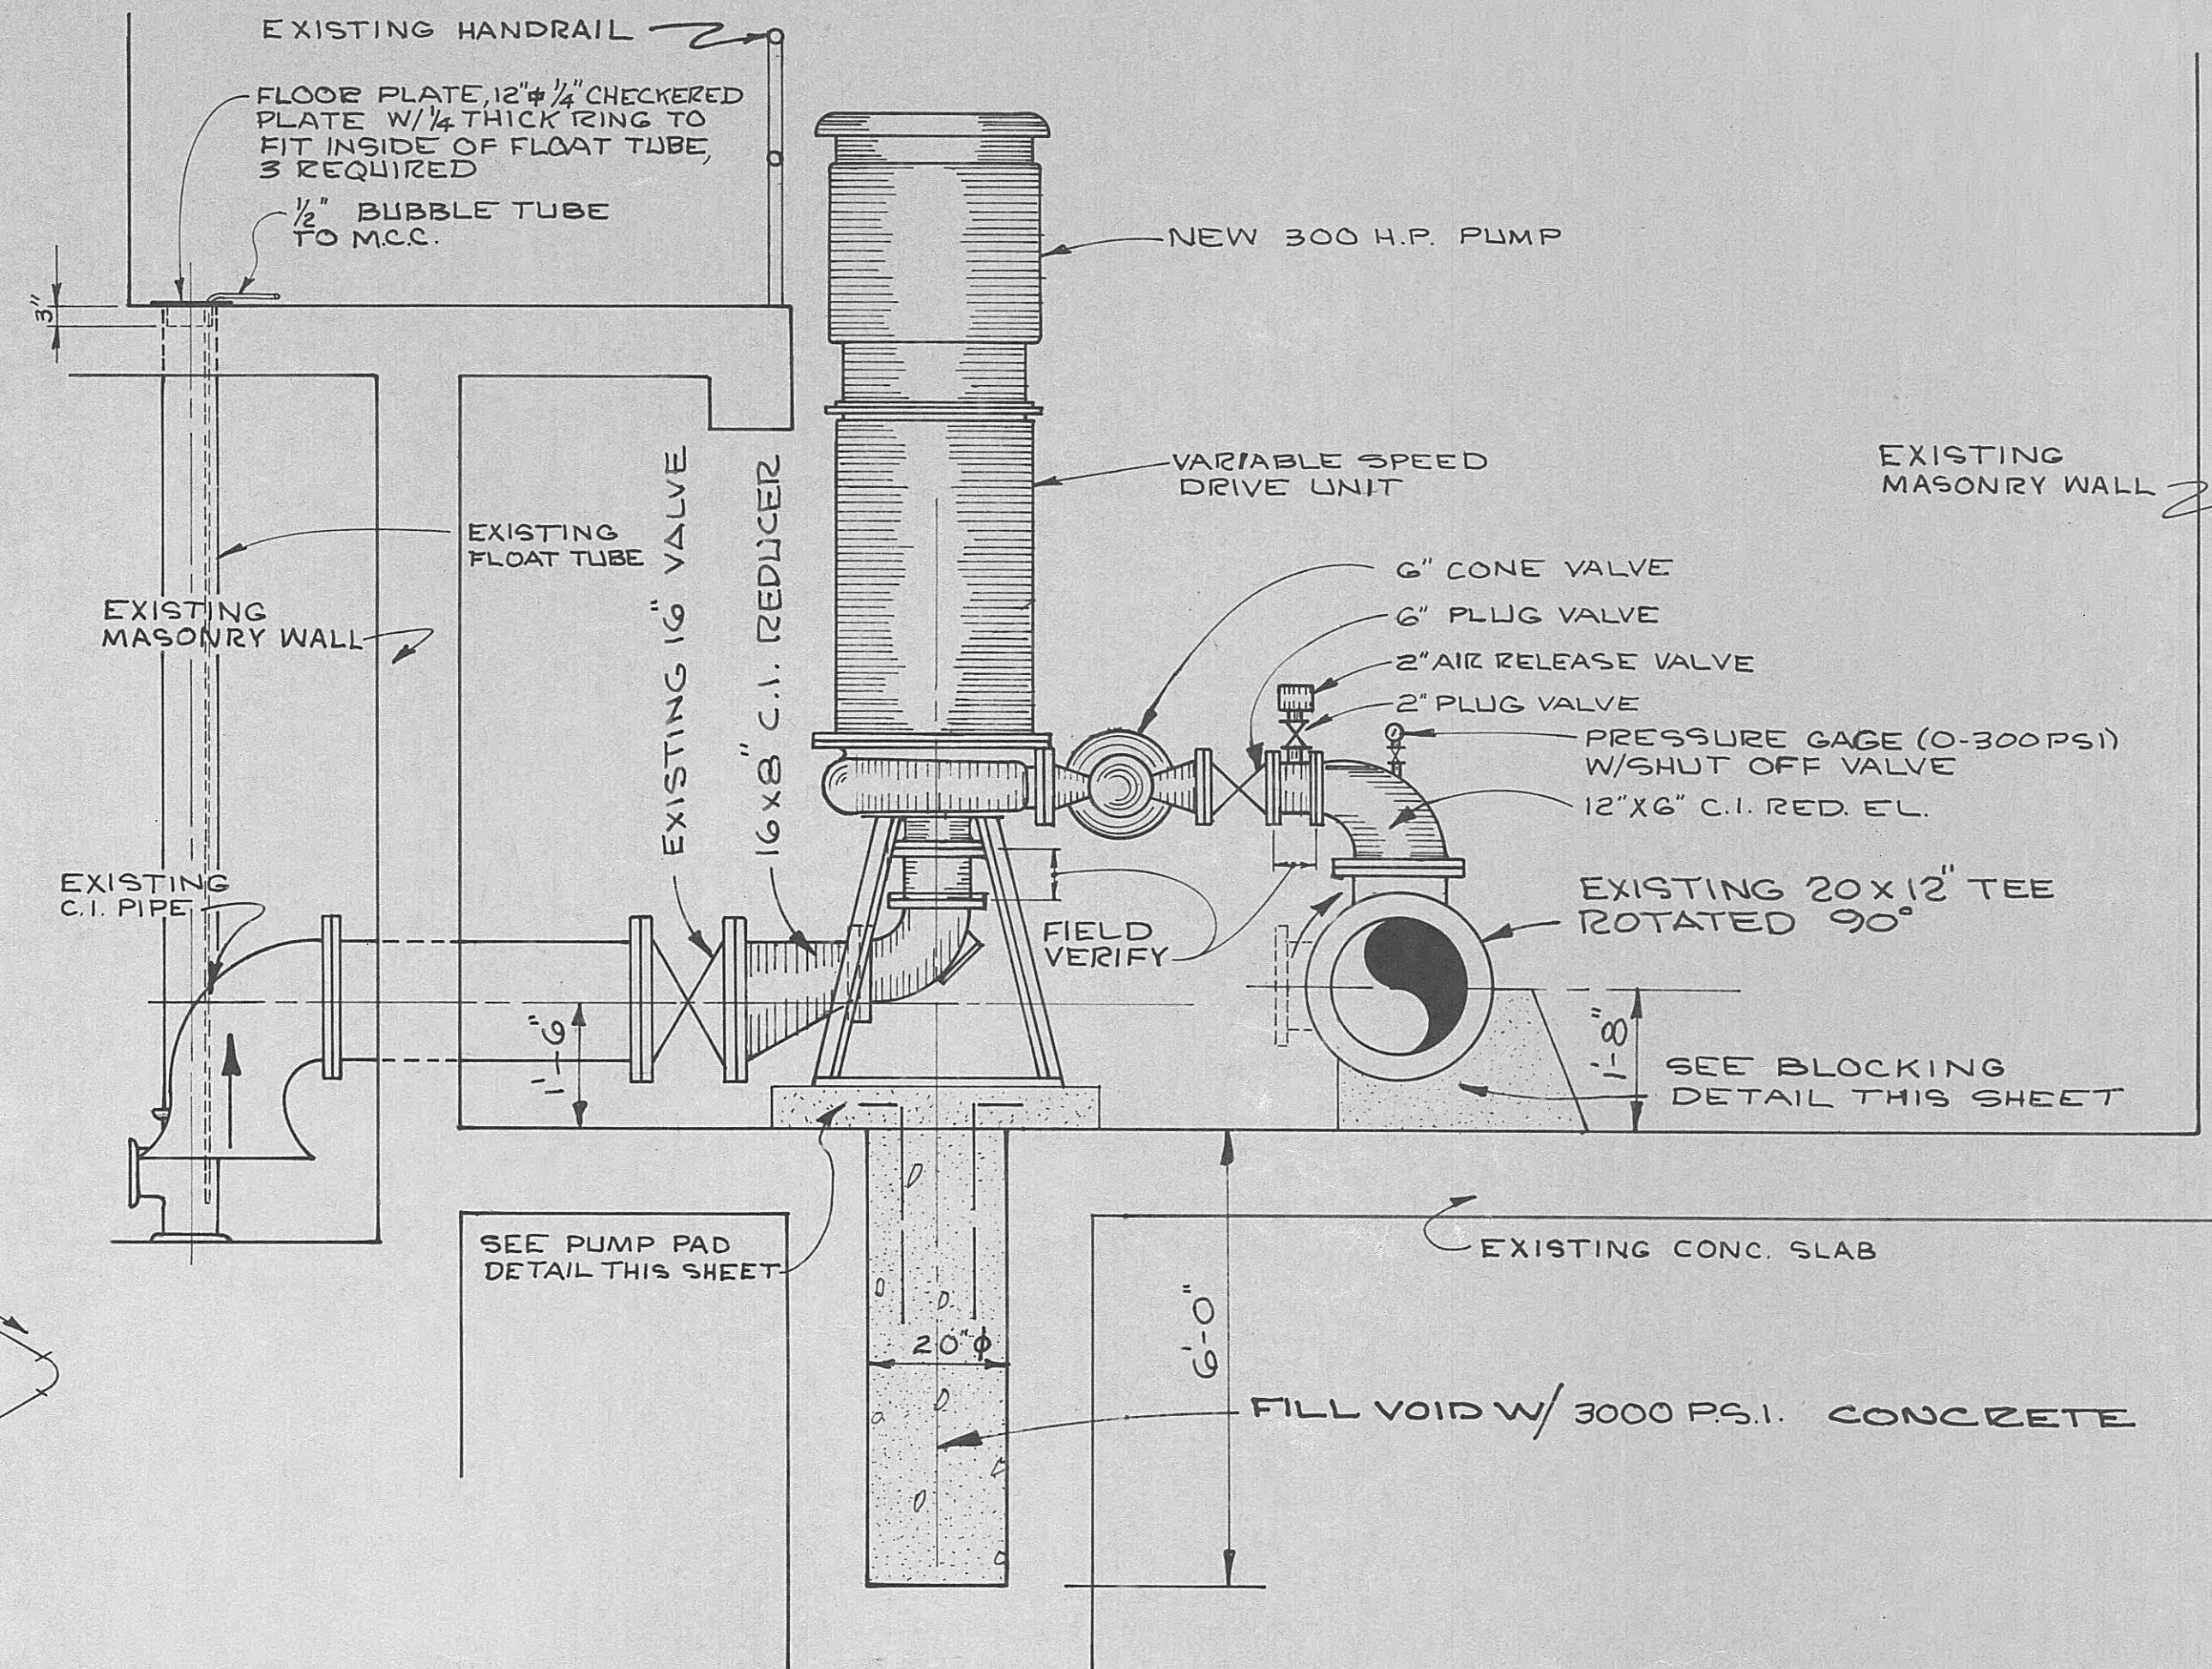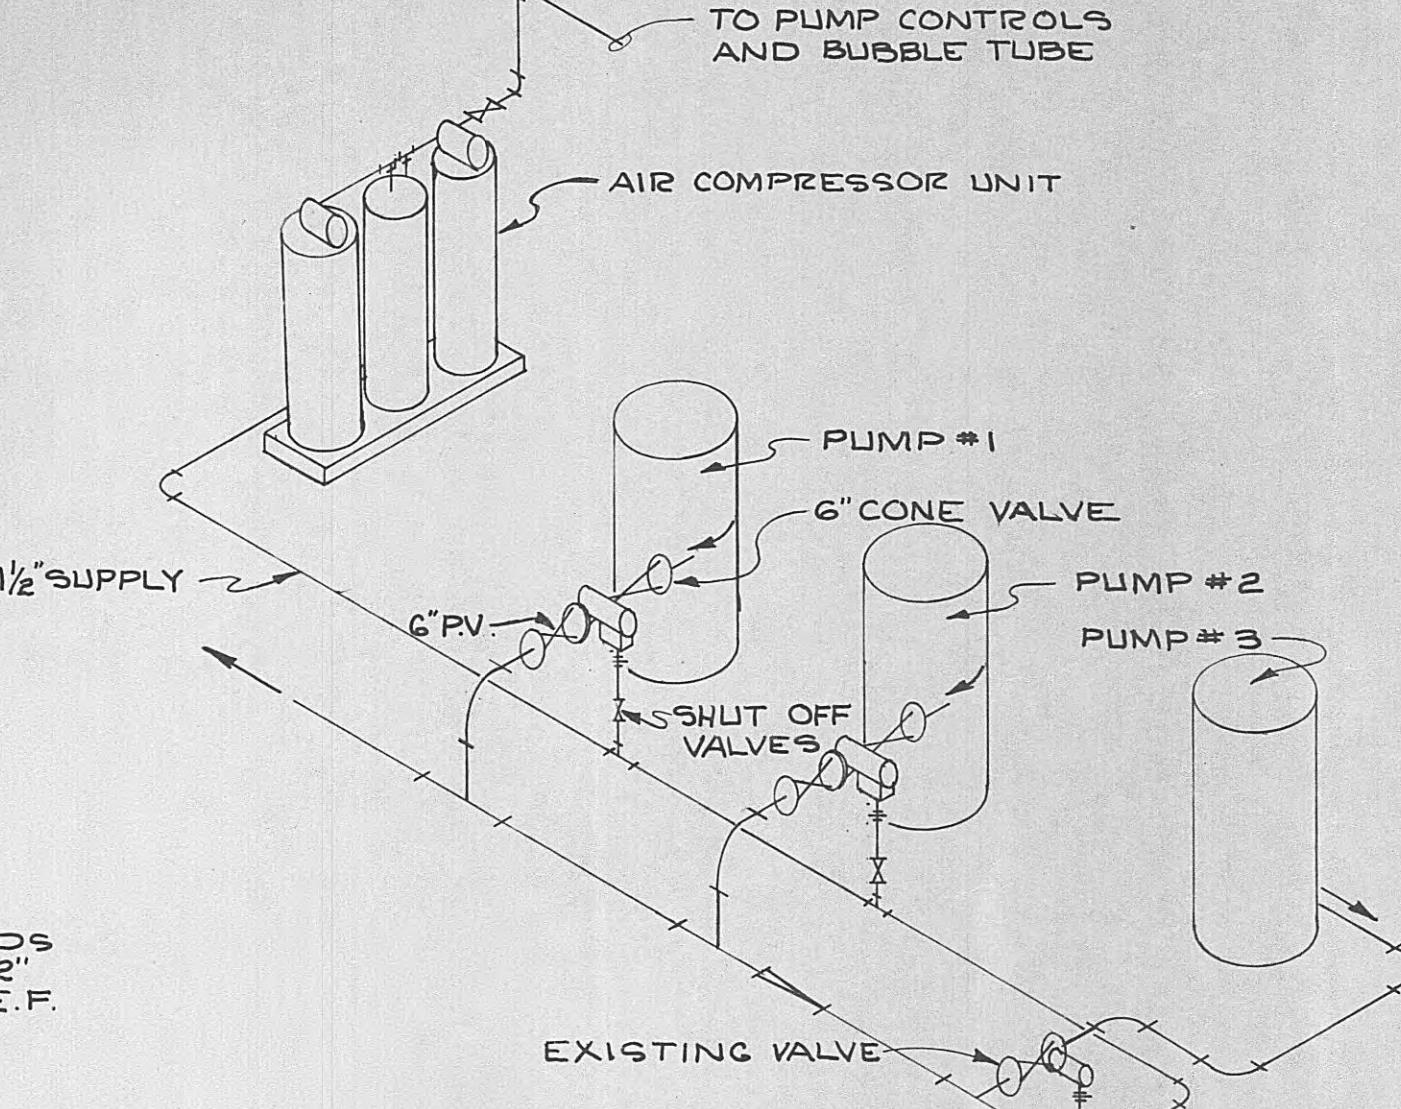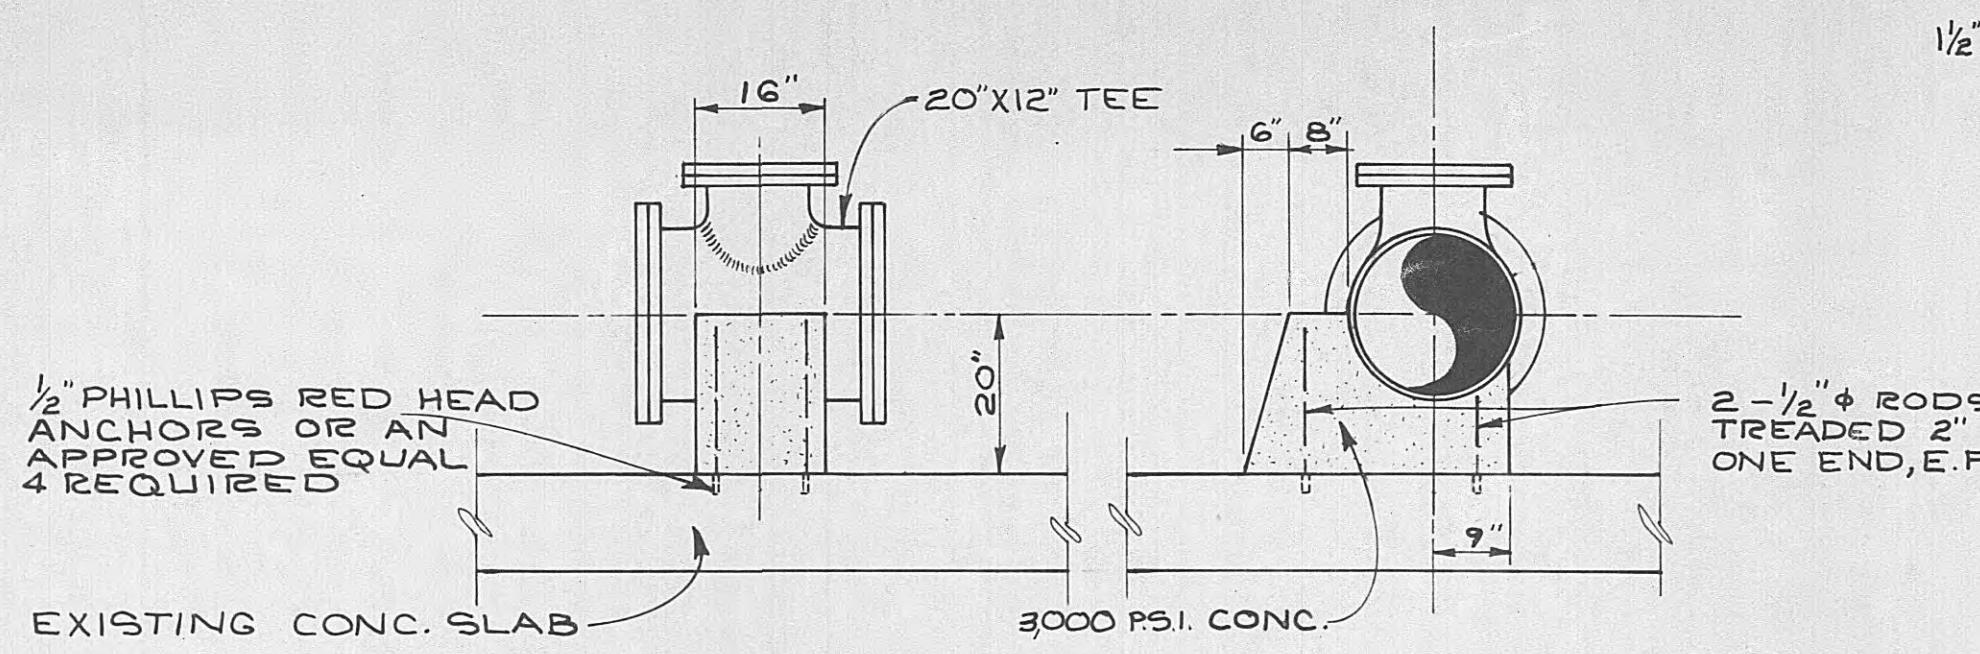

BLOCKING DETAIL


SCALE 1/2" = 1'-0"

PIPING DIAGRAM FOR AIR COMPRESSOR UNIT

SCALE NONE

GENERAL NOTES

1. PROVIDE CHAINS AND LOCKS FOR PLUG VALVES ON PUMP DISCHARGE.
2. CONVERT EXISTING VALVE TO AIR/OIL OPERATION.

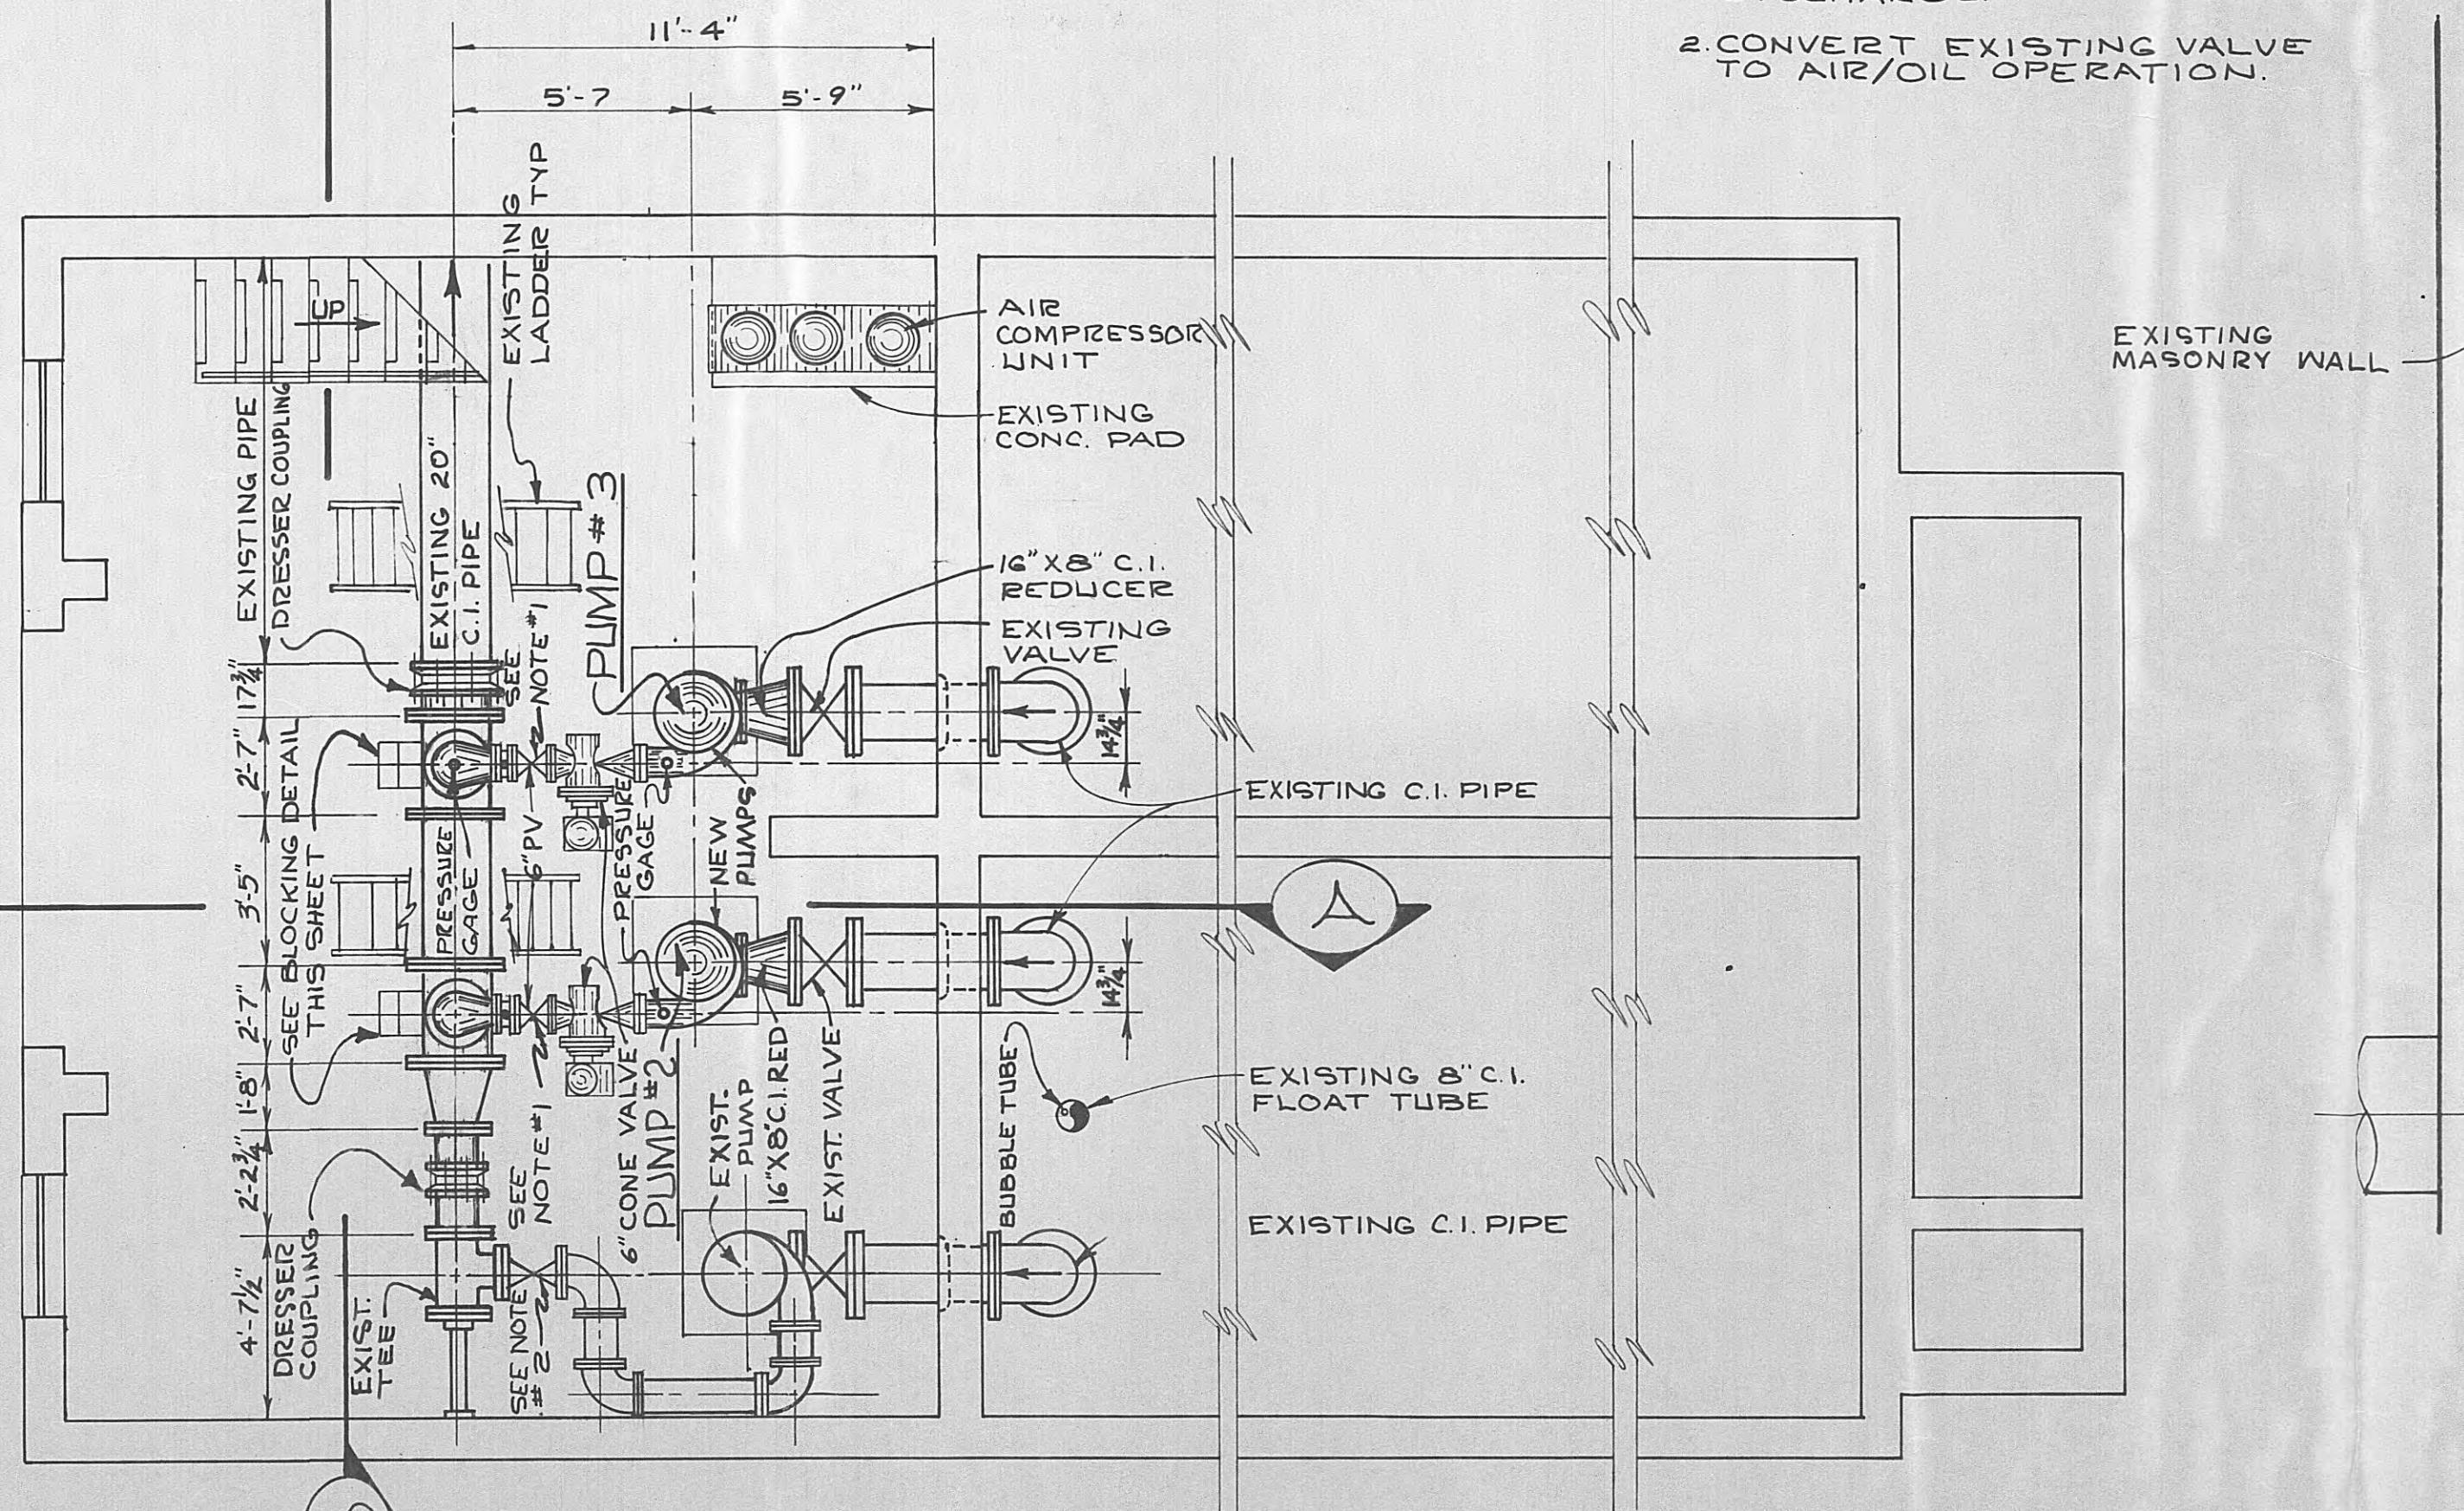


FLOOR PLAN

SCALE 1/4" = 1'-0"

LEGEND

- EXISTING EQUIPMENT TO REMAIN
- NEW EQUIPMENT TO BE INSTALLED, OWNER TO FURNISH TWO (2) G CONE VALVE


MODIFICATIONS TO EXISTING PUMP STATION No. 2

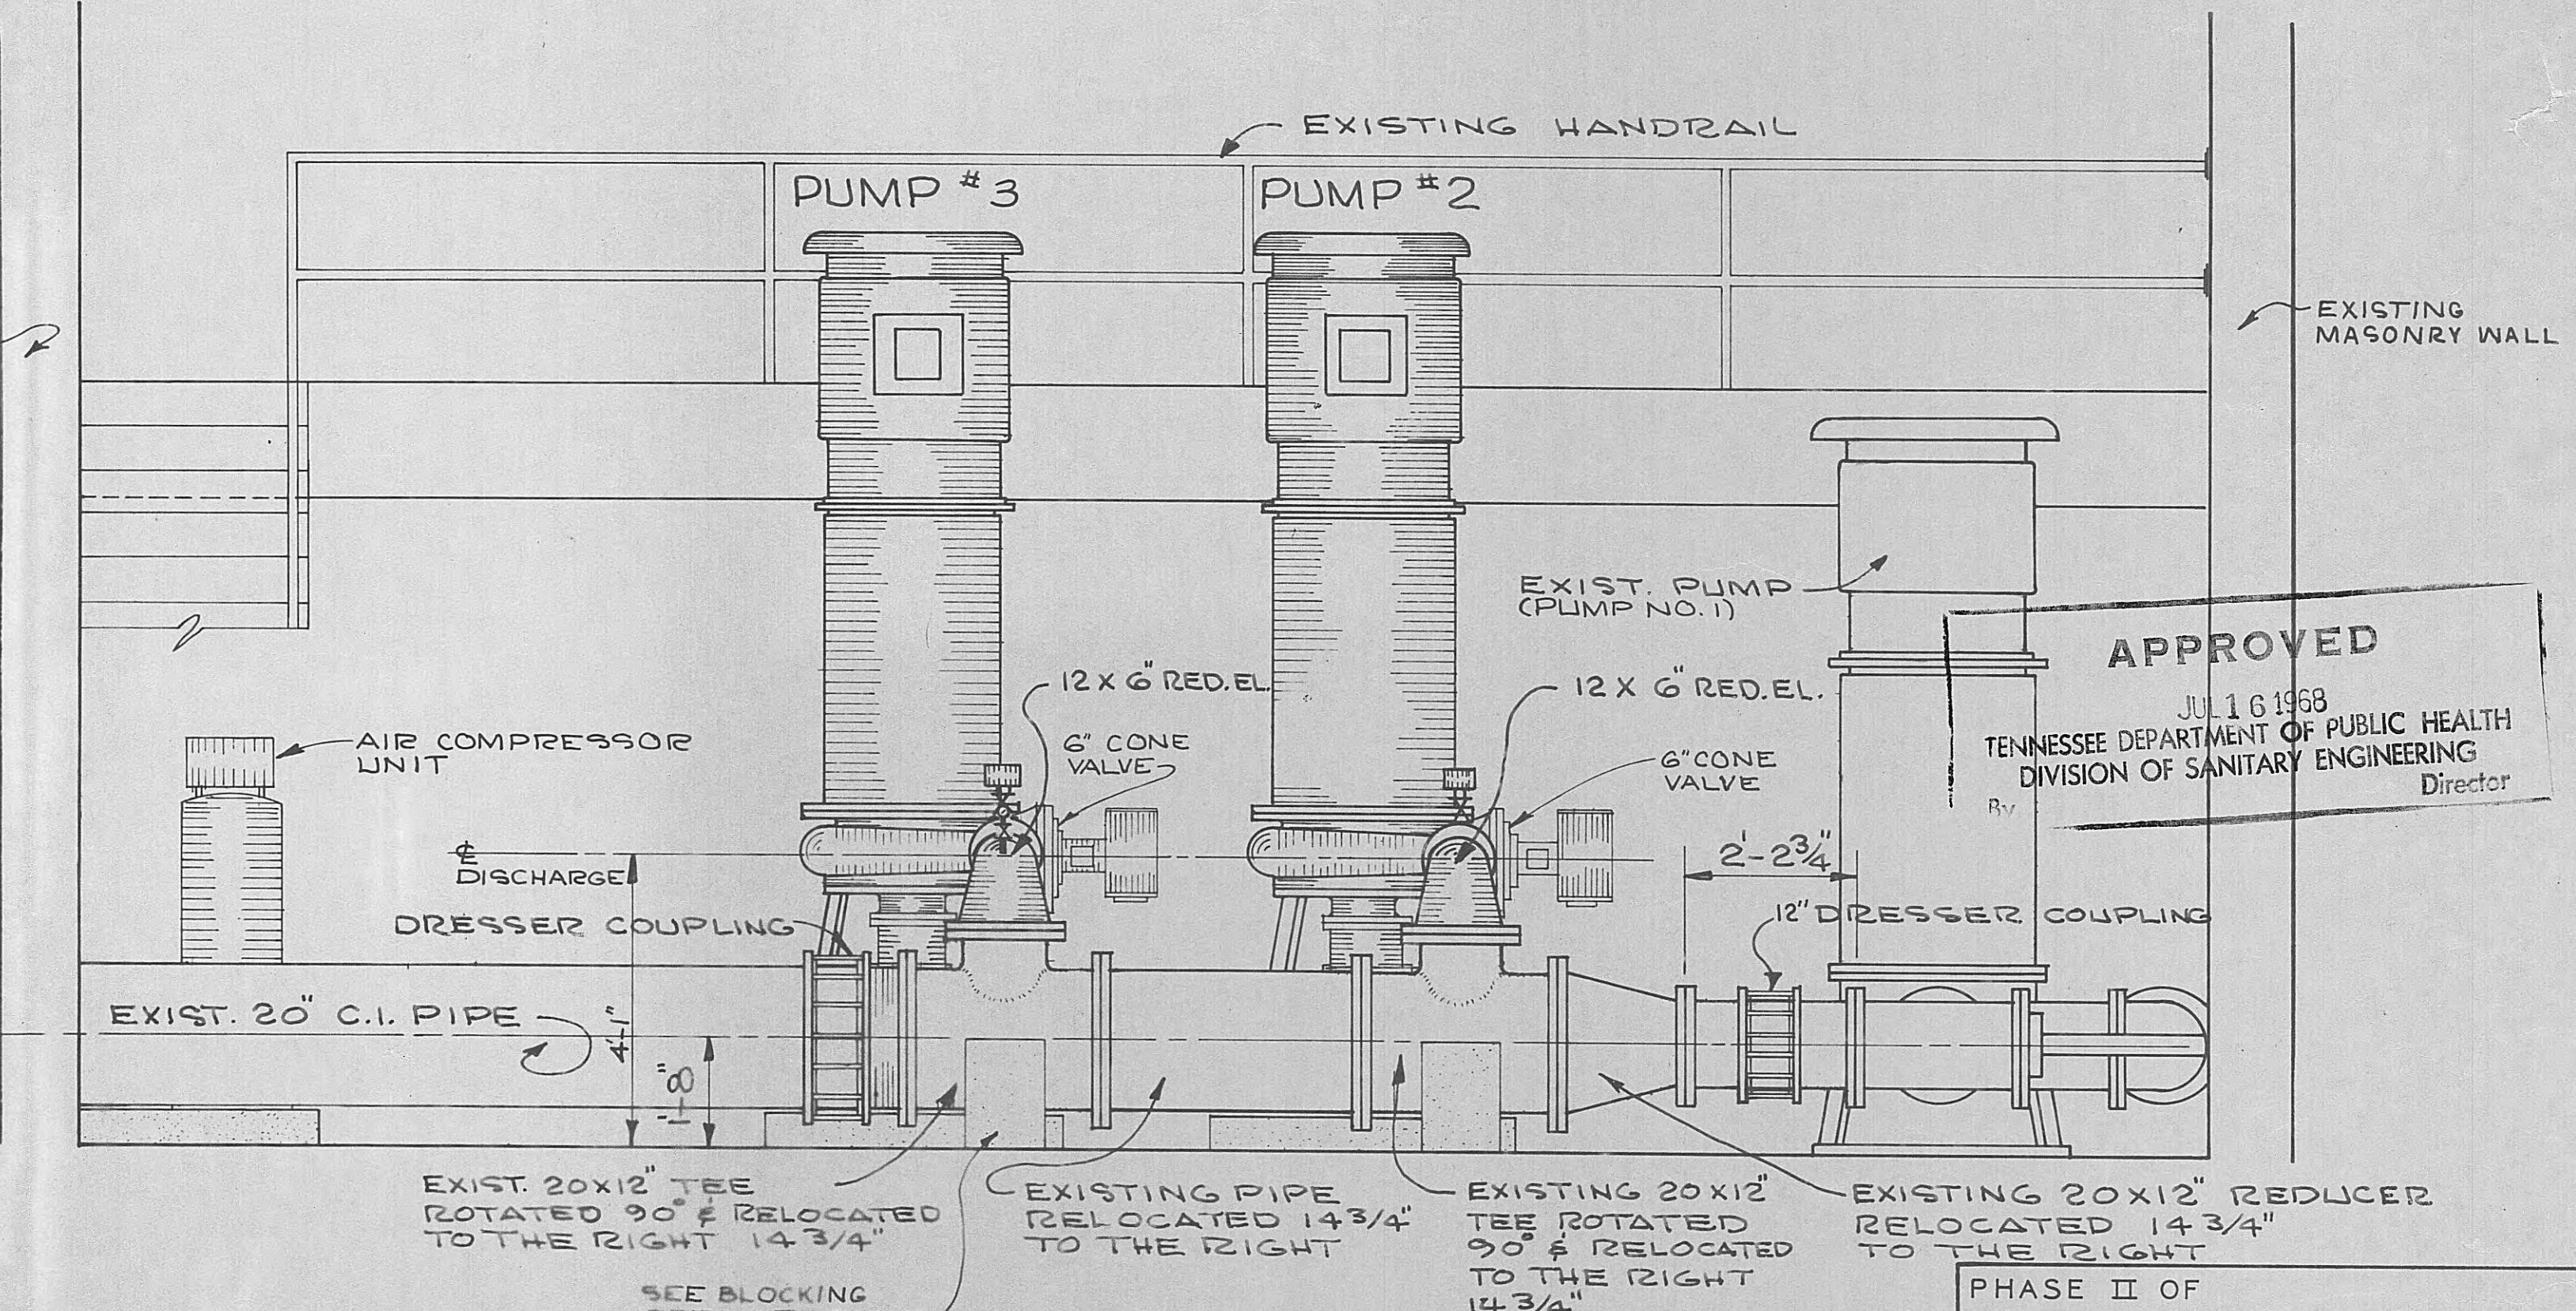

SECTION "B"-B

SCALE

1/2" = 1'-0" FOR APPROVAL

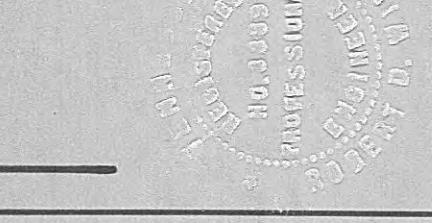

PHASE II OF
MODIFICATIONS TO
EFFLUENT PUMPING SYSTEM
FOR CITY OF HARRIMAN TENNESSEE
ROANE COUNTY


BLACK, CROW AND EIDSNESS, INC.
ENGINEERS
GAINESVILLE FLORIDA

DRAWN BY: R.O.E. DATE: JUNE 14, 1968
CHECKED BY: FILE NO.: 427-68-2

SCALE AS NOTED

MODIFICATIONS TO
EXISTING PUMP
STATION # 2

SHEET
NO.
M-2

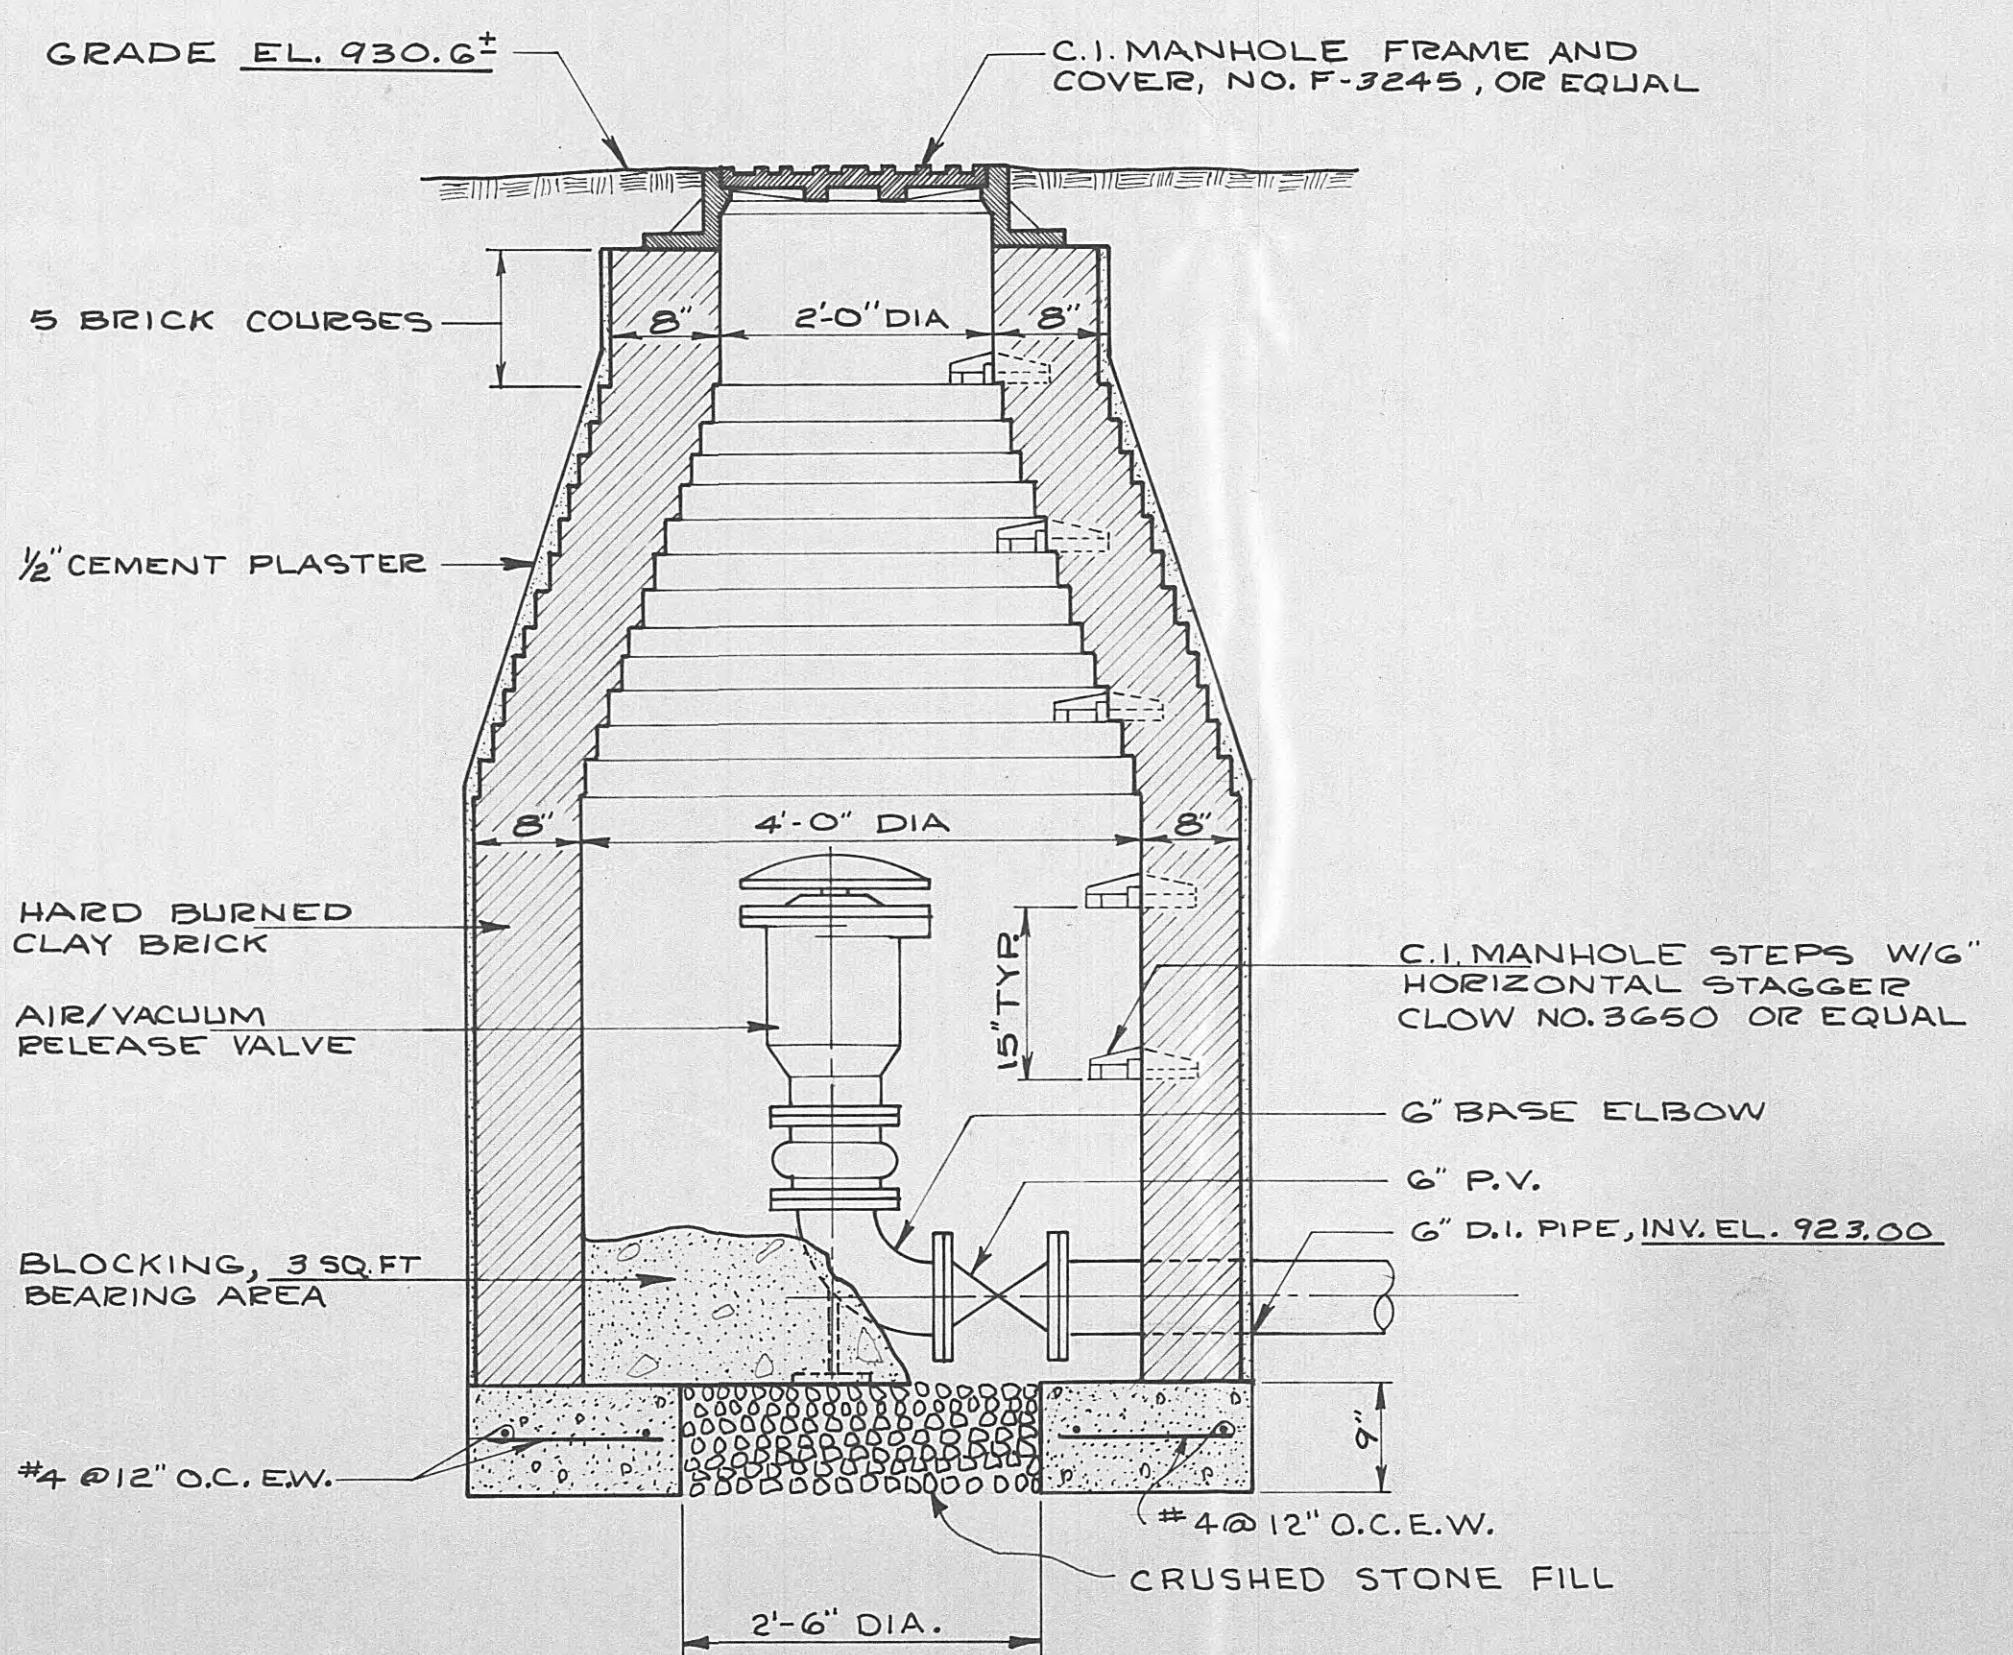


AIR RELEASE VALVE PIT

SCALE
 $\frac{3}{4} = 1'-0"$


APPROVED
JUL 16 1968
TENNESSEE DEPARTMENT OF PUBLIC HEALTH
DIVISION OF SANITARY ENGINEERING
By Director

PHASE II OF	
MODIFICATIONS TO	
EFFLUENT PUMPING SYSTEM	
FOR CITY OF HARRIMAN TENNESSEE	
TENNESSEE	
BLACK, CROW AND EIDSNESS, INC.	
ENGINEERS	
GAINESVILLE FLORIDA	
DRAWN BY: R.O.E.	DATE:
CHECKED BY: FILE NO.: 479-68-2	
SCALE: $\frac{3}{4} = 1'-0"$	
SHEET NO. M-3	
AIR RELEASE VALVE PIT	

FOR APPROVAL

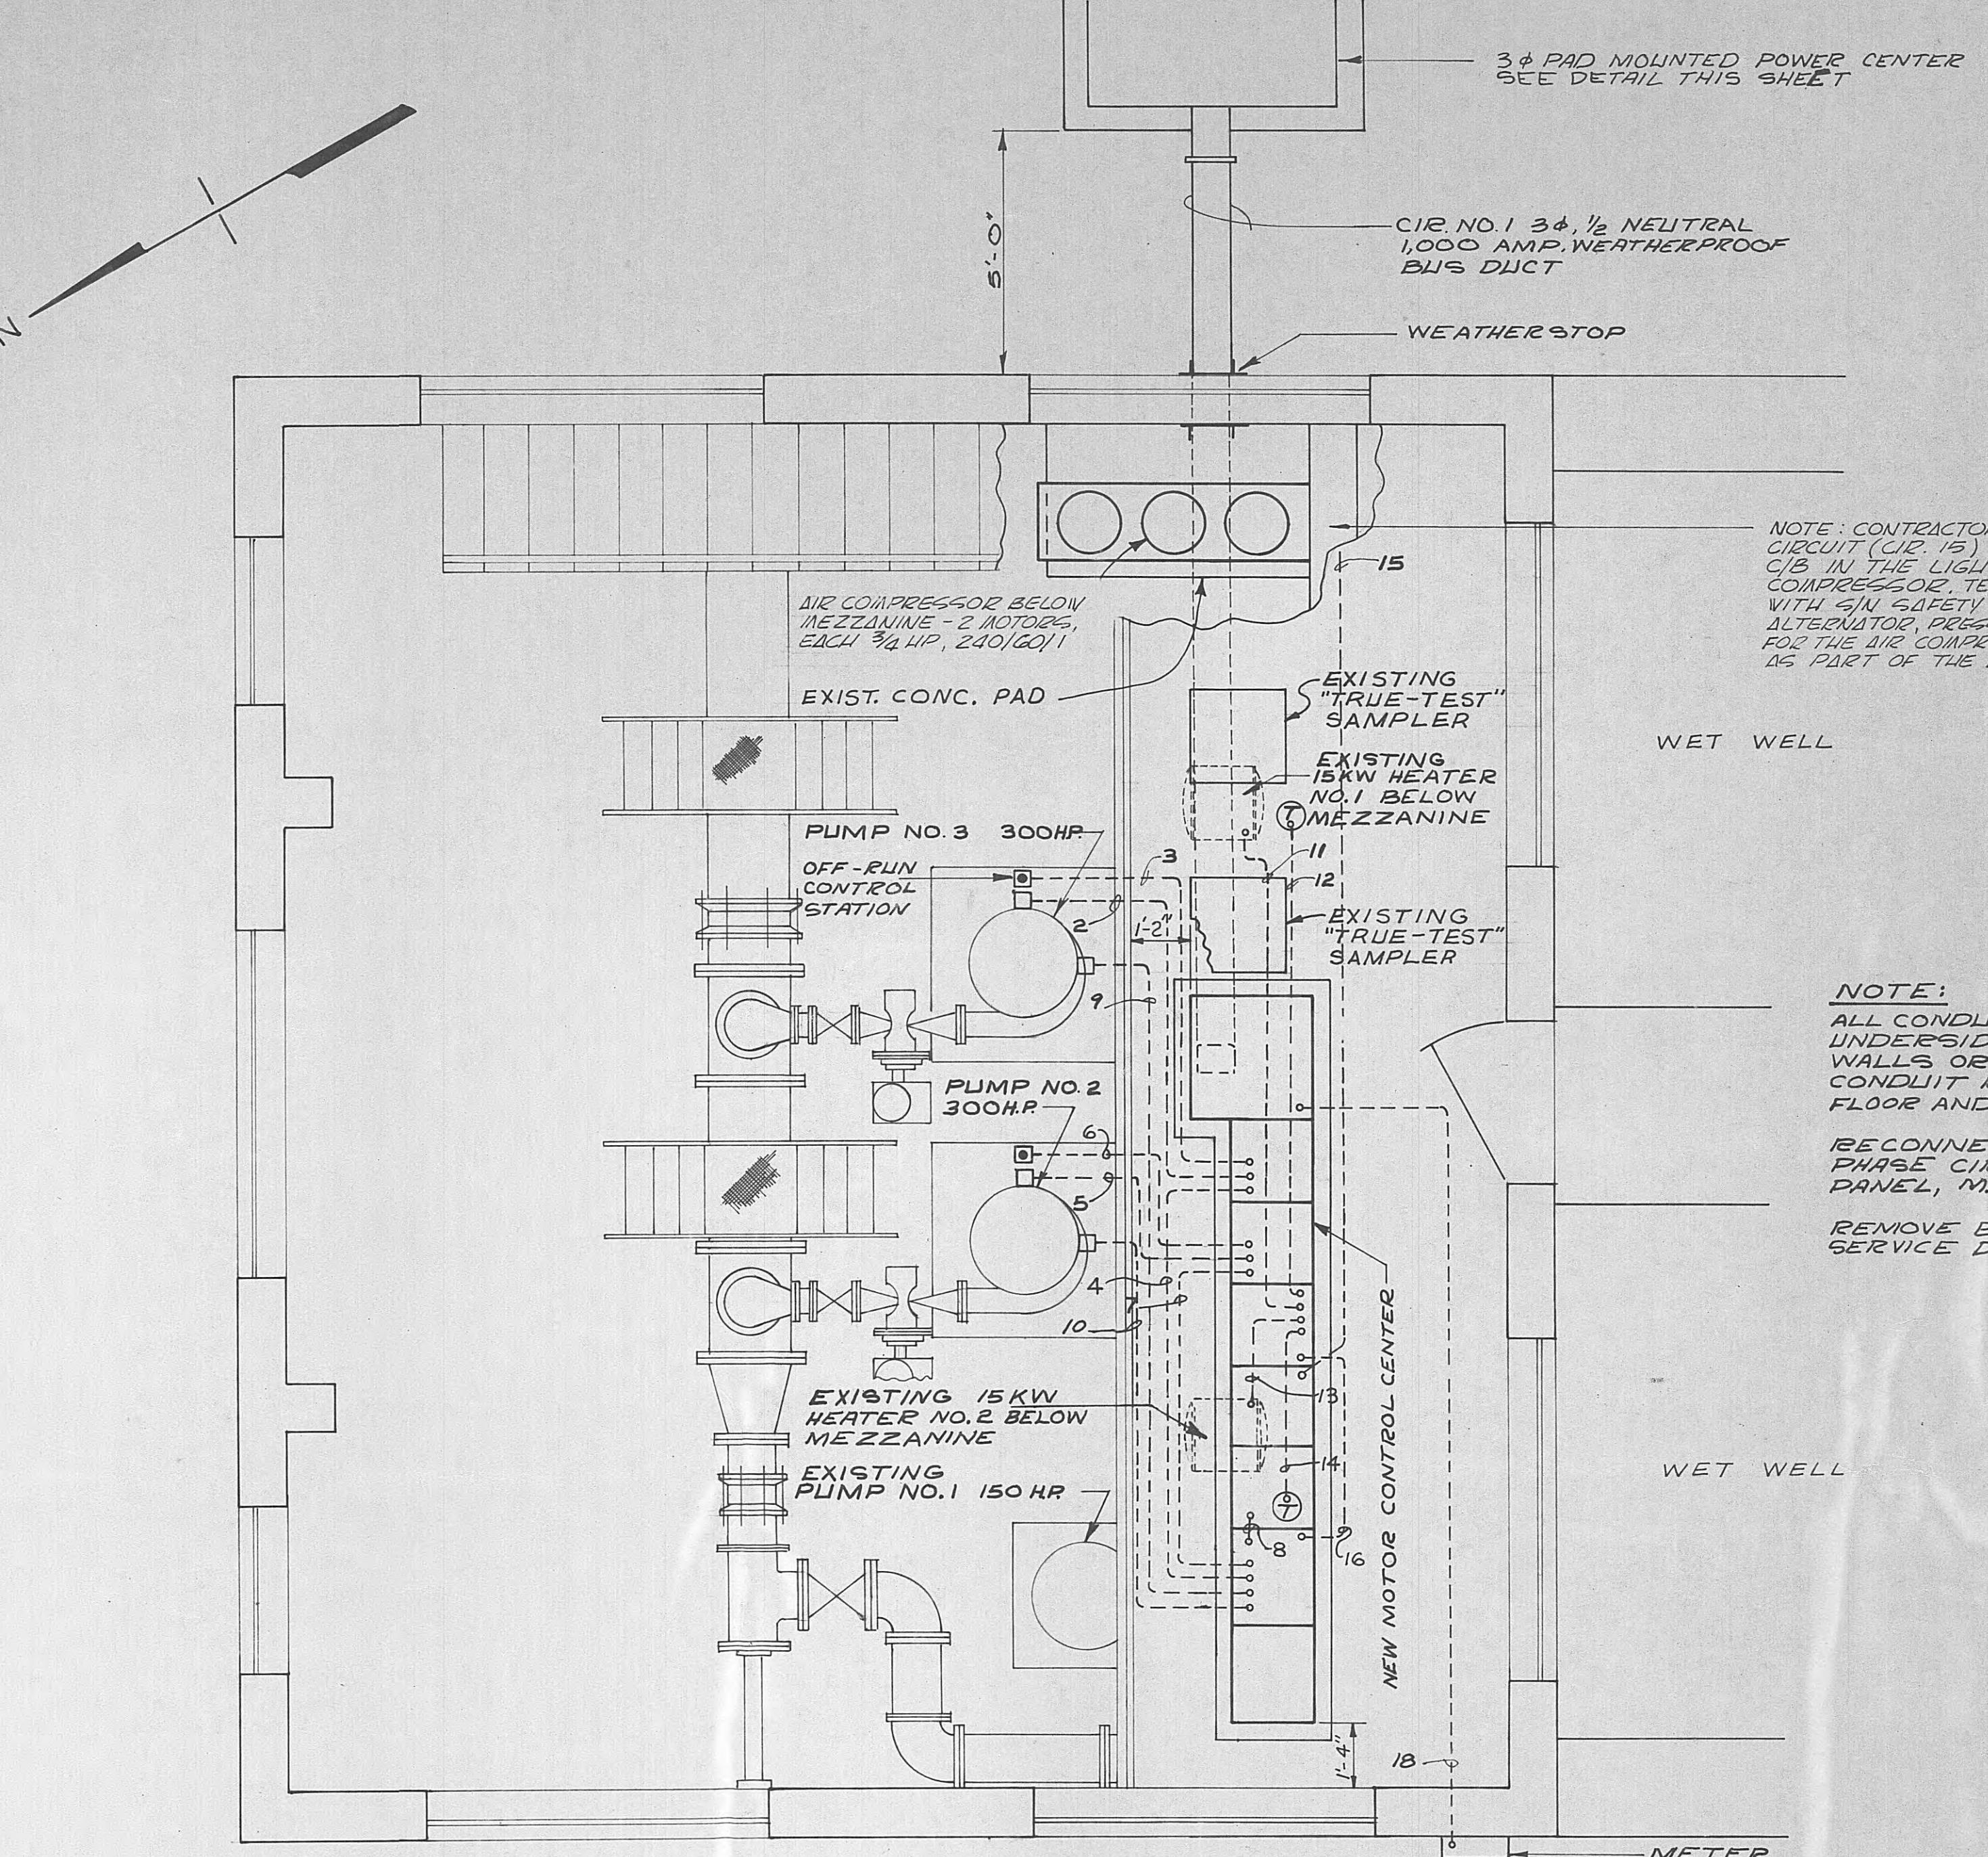

CIRCUIT NO.	FROM	TO	POWER AND CONTROL WIRING SCHEDULE			
			HORSEPOWER	VOLTS	AMPS	REMARKS
1	SERVICE TRANSFORMER	MCC. UNIT NO. 4	—	480	979	1000A BUS
2	M.C.C. UNIT NO. 6	PUMP NO. 3	300	480	370	6 1/2" 350 MCM 2 1/2"
3	M.C.C. UNIT NO. 6	PUMP NO. 3 C.S.	—	120	—	2 1/2" NO. 12 1/2"
4	M.C.C. UNIT NO. 6	VARIABLE SPEED PANEL	—	120	—	6 1/2" NO. 12 1"
5	M.C.C. UNIT NO. 7	PUMP NO. 2	300	480	370	6 1/2" 350 MCM 2 1/2"
6	M.C.C. UNIT NO. 7	PUMP NO. 2 C.S.	—	120	—	2 1/2" NO. 12 1/2"
7	M.C.C. UNIT NO. 7	VARIABLE SPEED PANEL	—	120	—	6 1/2" NO. 12 1"
8	VARIABLE SPEED PANEL	EXIST. PUMP NO. 1 M.S.	—	120	—	6 1/2" NO. 12 1"
9	VARIABLE SPEED PANEL	PUMP NO. 2 MAG. DRIVE	—	—	—	BY DRIVE MFG. 3/4"
10	VARIABLE SPEED PANEL	PUMP NO. 3 MAG. DRIVE	—	—	—	BY DRIVE MFG. 3/4"
11	M.C.C. UNIT NO. 8	HEATER NO. 1 15KW	—	480	23	3 1/2" NO. 10 3/4"
12	M.C.C. UNIT NO. 8	HEATER NO. 1 THERMOSTAT	—	120	—	2 1/2" NO. 12 1/2"
13	M.C.C. UNIT NO. 9	HEATER NO. 2 15KW	—	480	23	3 1/2" NO. 10 3/4"
14	M.C.C. UNIT NO. 9	HEATER NO. 2 THERMOSTAT	—	120	—	2 1/2" NO. 12 1/2"
15	M.C.C. UNIT NO. 10	AIR COMPRESSOR	—	240	12	3 1/2" NO. 12 3/4"
16	M.C.C. UNIT NO. 11	VARIABLE SPEED PANEL	—	480	5	2 1/2" NO. 12 1/2"
17	POWER POLE	POWER CENTER, UNIT NO. 0	—	13200	43	BY POWER CO. 3 1/2"
18	M.C.C. UNIT NO. 5	POWER COMPANY METER	—	—	—	BY POWER CO. 1"

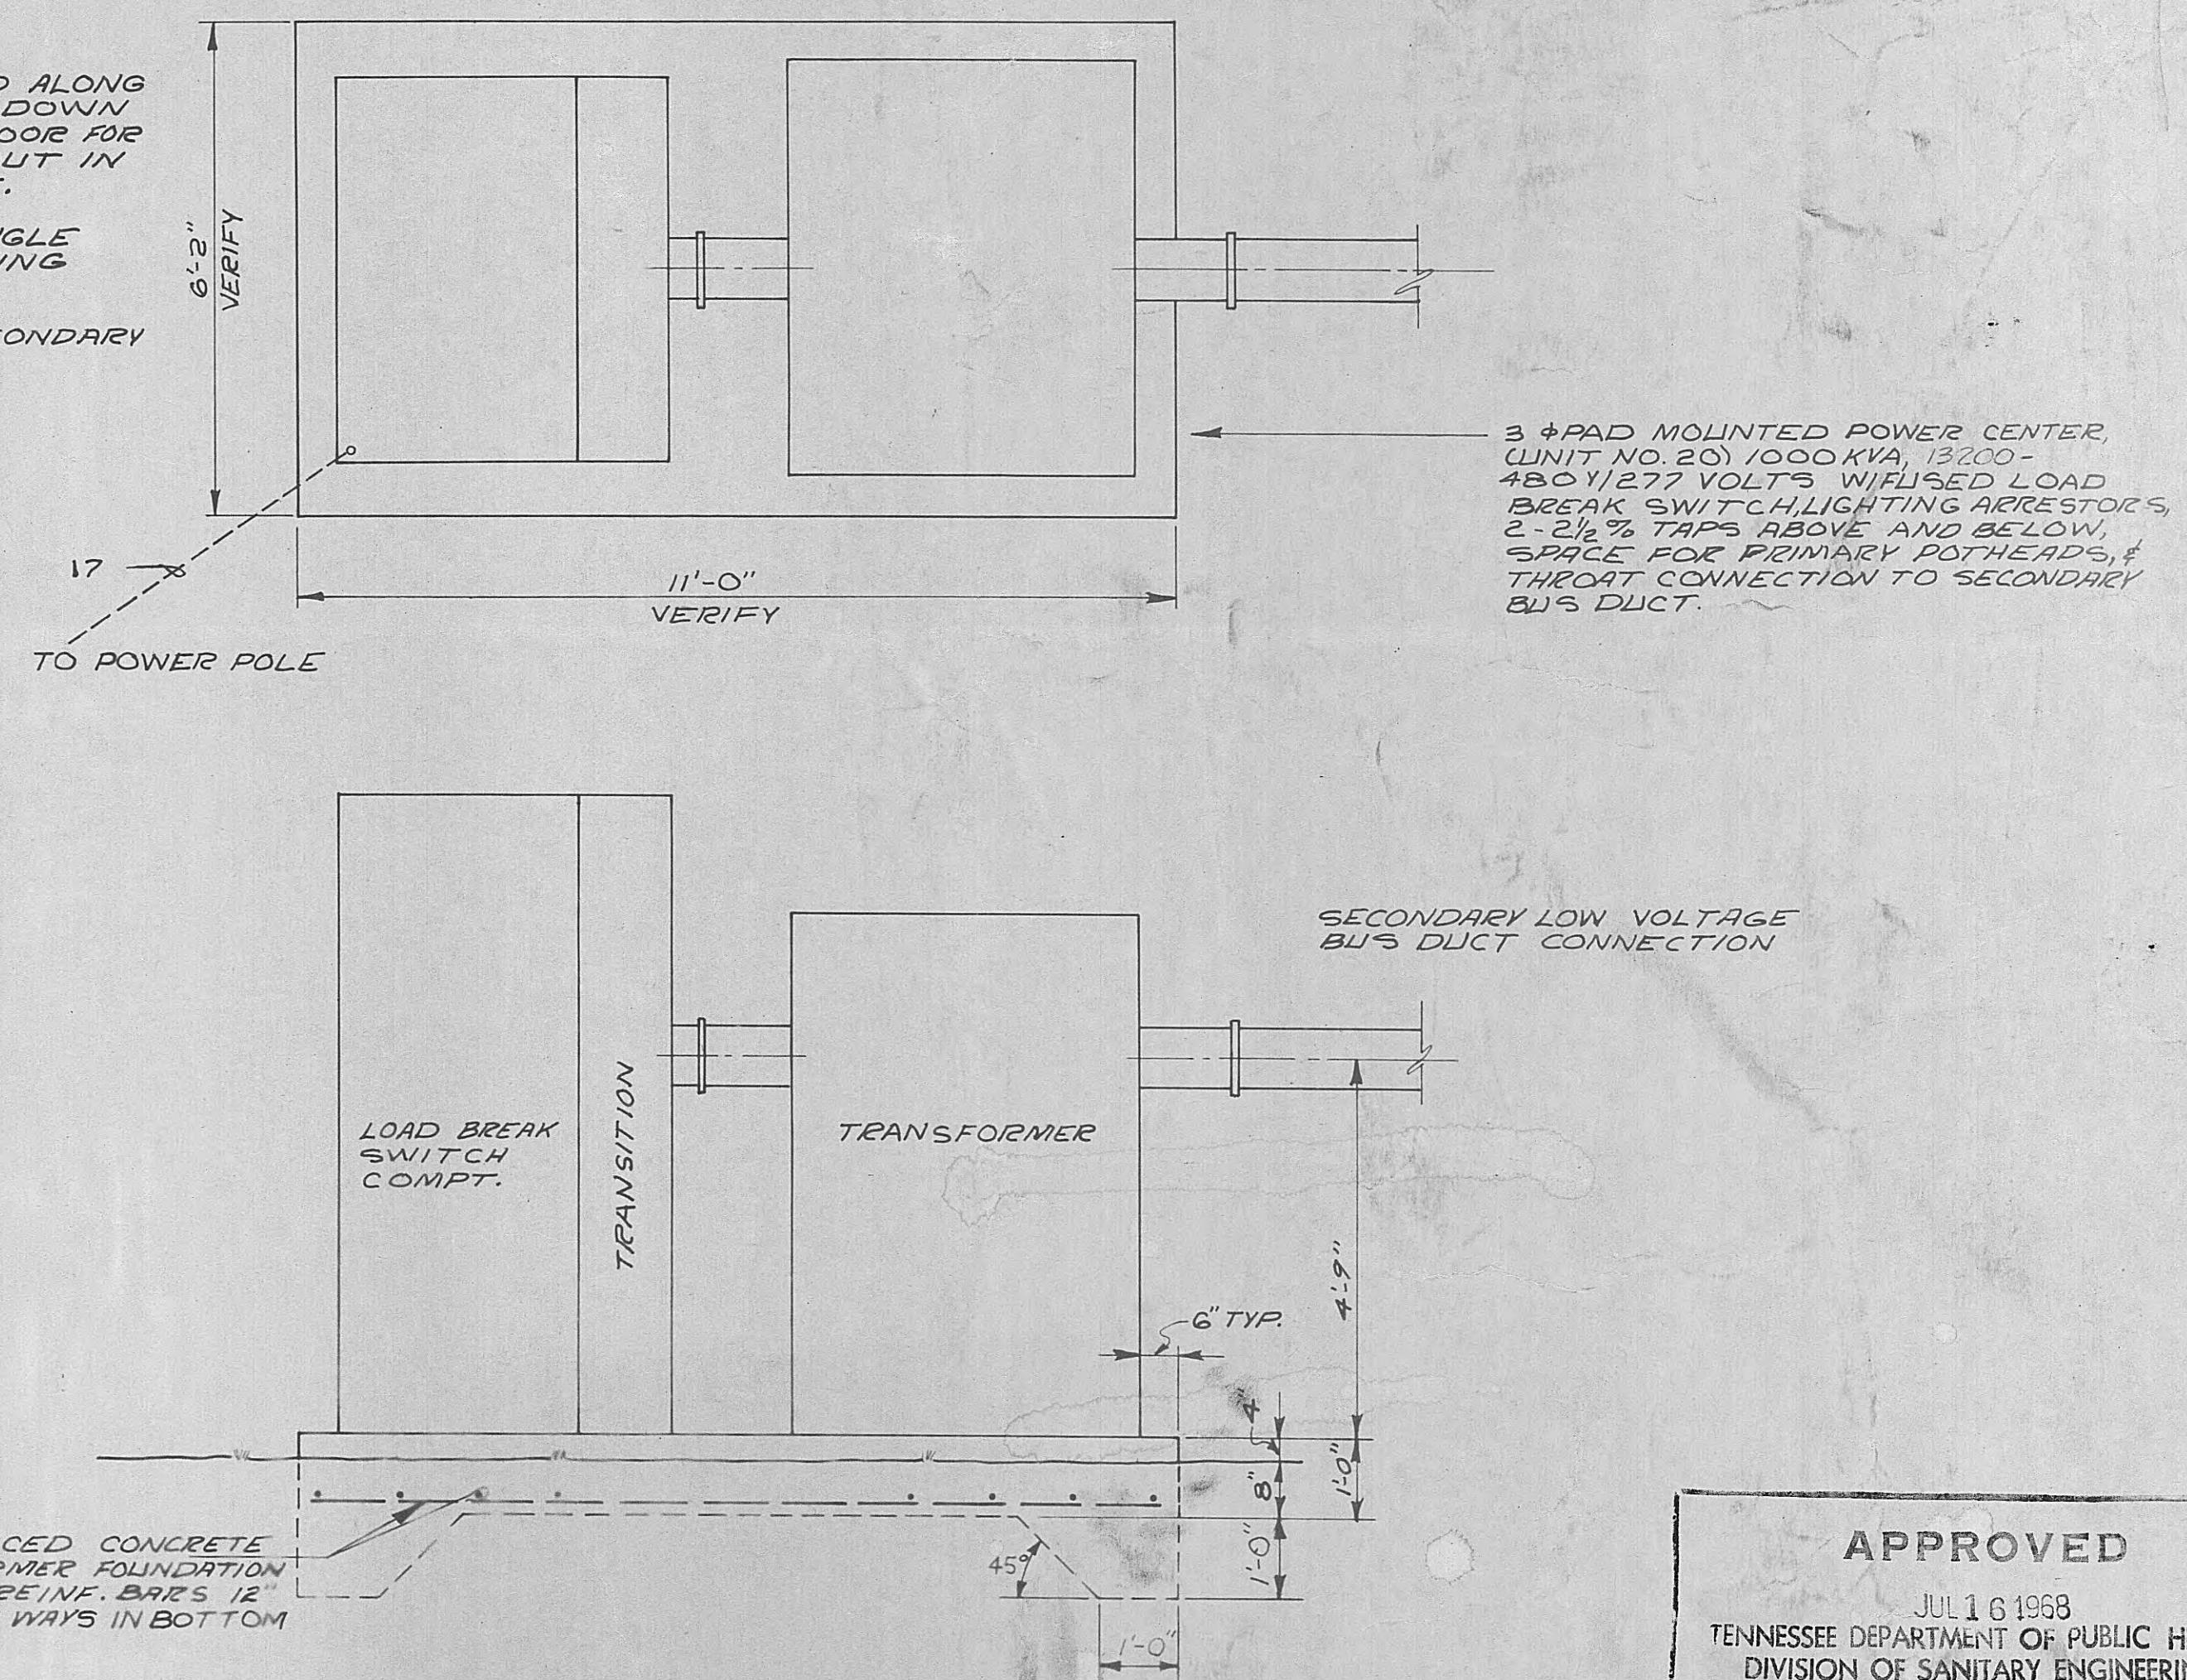

POWER CENTER DETAIL
SCALE NONE

APPROVED
JUL 16 1968
TENNESSEE DEPARTMENT OF PUBLIC HEALTH
DIVISION OF SANITARY ENGINEERING
By Director

PHASE II OF	
MODIFICATIONS TO	
EFFLUENT PUMPING SYSTEM	
FOR CITY OF HARRIMAN TENNESSEE	
ROANE COUNTY TENNESSEE	
BLACK, CROW AND EIDSNESS, INC.	
ENGINEERS	
GAINESVILLE FLORIDA	
DRAWN BY: ROE	DATE:
CHECKED BY:	FILE NO.: 429-68-2
SCALE: $\frac{1}{16}$ = 1'-0"	
ELECTRICAL PLAN	
SHEET NO. E-1	



FOR APPROVAL


NO.	DESCRIPTION	DATE
REVISIONS		

MOTOR CONTROL CENTER EQUIPMENT SCHEDULE

UNIT NO.	DESCRIPTION OF UNIT	VOLTAGE	HP	FRAME	FUSE OR SB	AMPS	INSTANTANEOUS	AMPS	TRIP	TELETYPE	WIRING TYPE	DESIGNATION	POLES	AMP LOAD	NEMA TYPE	NEMA SIZE	CONTROL	DIAGRAM	REMARKS
①	RELAY PANEL	-	-	-	-	-	-	-	-	-	-	-	-	-	-	-	-	-	
②	NEG SEQUENCE RELAY	-	-	-	-	-	-	-	-	-	-	-	-	-	-	-	-	GE TYPE NBV	
③	PHASE REV-UNDERVOLTAGE RELAY	-	-	-	-	-	-	-	-	-	-	-	-	-	-	-	-	GE TYPE ICR	
④	CIRCUIT BREAKER	480	-	1600	1600	-	ET	AK50	3	979	1	-	-	-	-	-	-	MAIN, SHUNT TRIP	
⑤	METERING CT'S	-	-	-	-	-	-	-	-	-	-	-	-	-	-	-	-	AS REQUIRED BY POWER CO.	
⑥	PINE COMB 96 MOTOR STARTER	480	300	1200	500	-	ET	THM	3	370	1	5	A	PUMP NO. 2	-	-	-	-	
⑦	PINE COMB 96 MOTOR STARTER	480	300	1200	500	-	ET	THM	3	370	1	5	A	PUMP NO. 3	-	-	-	-	
⑧	CIRCUIT BREAKER	480	-	100	30	-	ET	TEF	3	23	1	-	-	HEATER NO. 1, 15 KW	-	-	-	-	
⑨	CIRCUIT BREAKER	480	-	100	30	-	ET	TEF	3	23	1	-	-	HEATER NO. 2, 15 KW	-	-	-	-	
⑩	SPACE	-	-	-	-	-	-	-	-	-	-	-	-	-	-	-	-	-	
⑪	CIRCUIT BREAKER	480	-	100	20	-	ET	TEF	2	5	1	-	-	MAGNETIC DRIVE CONTROL PNL.	-	-	-	-	
⑫	SPACE	-	-	-	-	-	-	-	-	-	-	-	-	-	-	-	-	-	
⑬	SPACE	-	-	-	-	-	-	-	-	-	-	-	-	-	-	-	-	-	
⑭	SPACE	-	-	-	-	-	-	-	-	-	-	-	-	-	-	-	-	-	
⑮	SPACE	-	-	-	-	-	-	-	-	-	-	-	-	-	-	-	-	-	
⑯	TRANSITION SECTION	480	-	-	-	-	-	-	-	-	-	-	-	BUS TRANSITION	-	-	-	-	
⑰	CIRCUIT BREAKER	480	-	100	60	-	ET	TEF	2	32	1	-	-	LIGHTING TRANSFORMER	-	-	-	-	
⑱	LIGHTING PANEL, 24 POLE	-	-	-	-	-	-	-	-	-	-	-	-	120/240, 1φ, 3W	-	-	-	-	
⑲	TRANSFORMER, 15 KVA	-	-	-	-	-	-	-	-	-	-	-	-	480-120/240, 1φ	-	-	-	-	
⑳	POWER CENTER, 1000 KVA	-	-	-	-	-	-	-	-	-	-	-	-	-	-	-	-	-	
㉑	FUSED SWITCH IN BUS	480	-	-	200	-	CLF	-	3	90	1	-	-	14,000 AMP MAX LET THROUGH	-	-	-	-	


TRANSITION SECTION FOR BUS CONNECTION NEW TO EXISTING MOTOR STARTER

NEW MOTOR CONTROL CENTER GE-7700 LINE

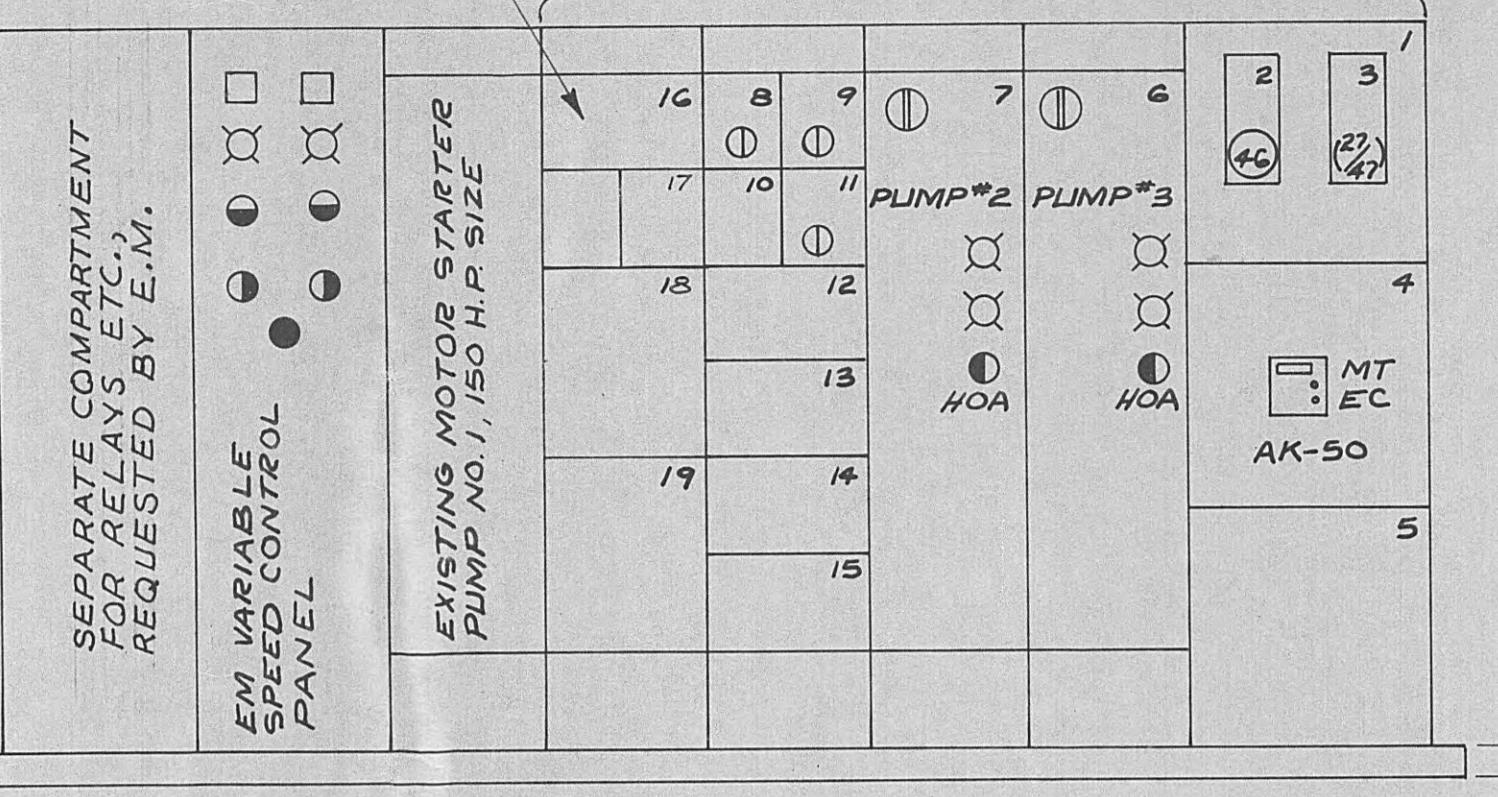


MOTOR CONTROL CENTER

SCALE NONE

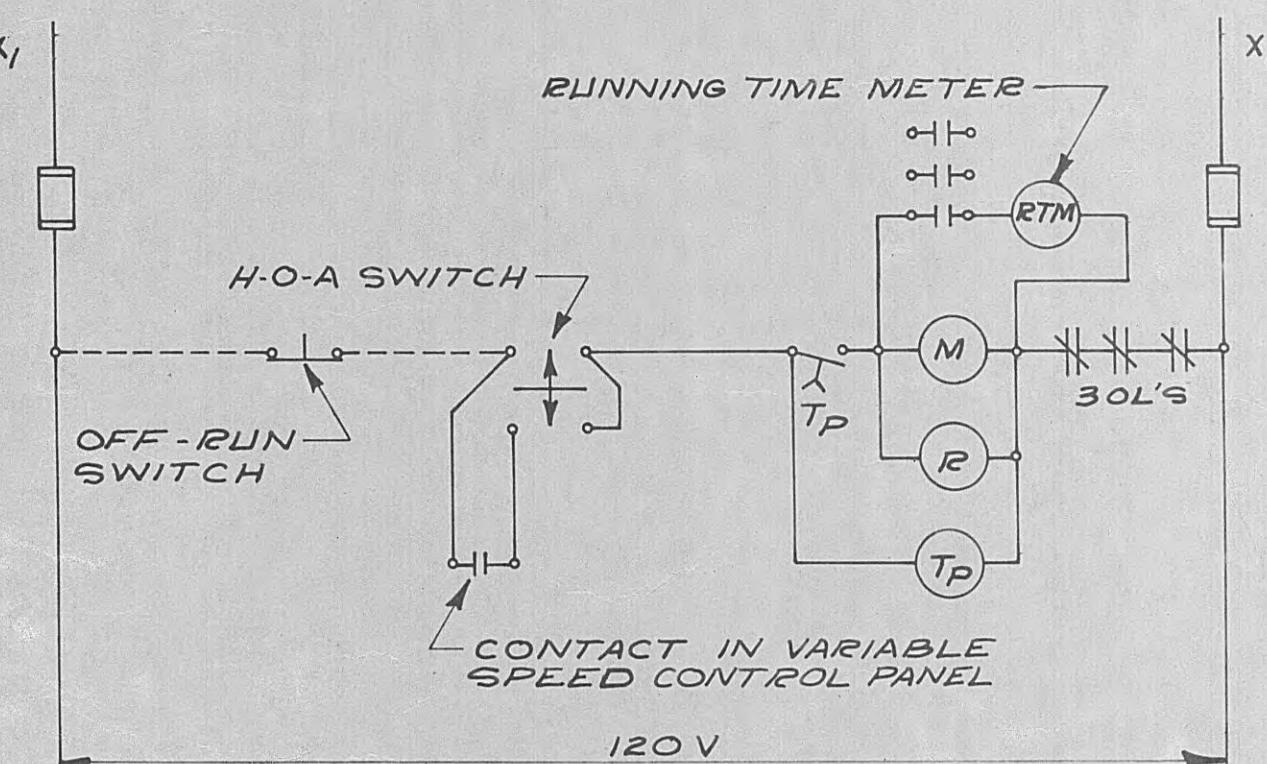


MOTOR CONTROL SCHEME "A"

SCALE NONE

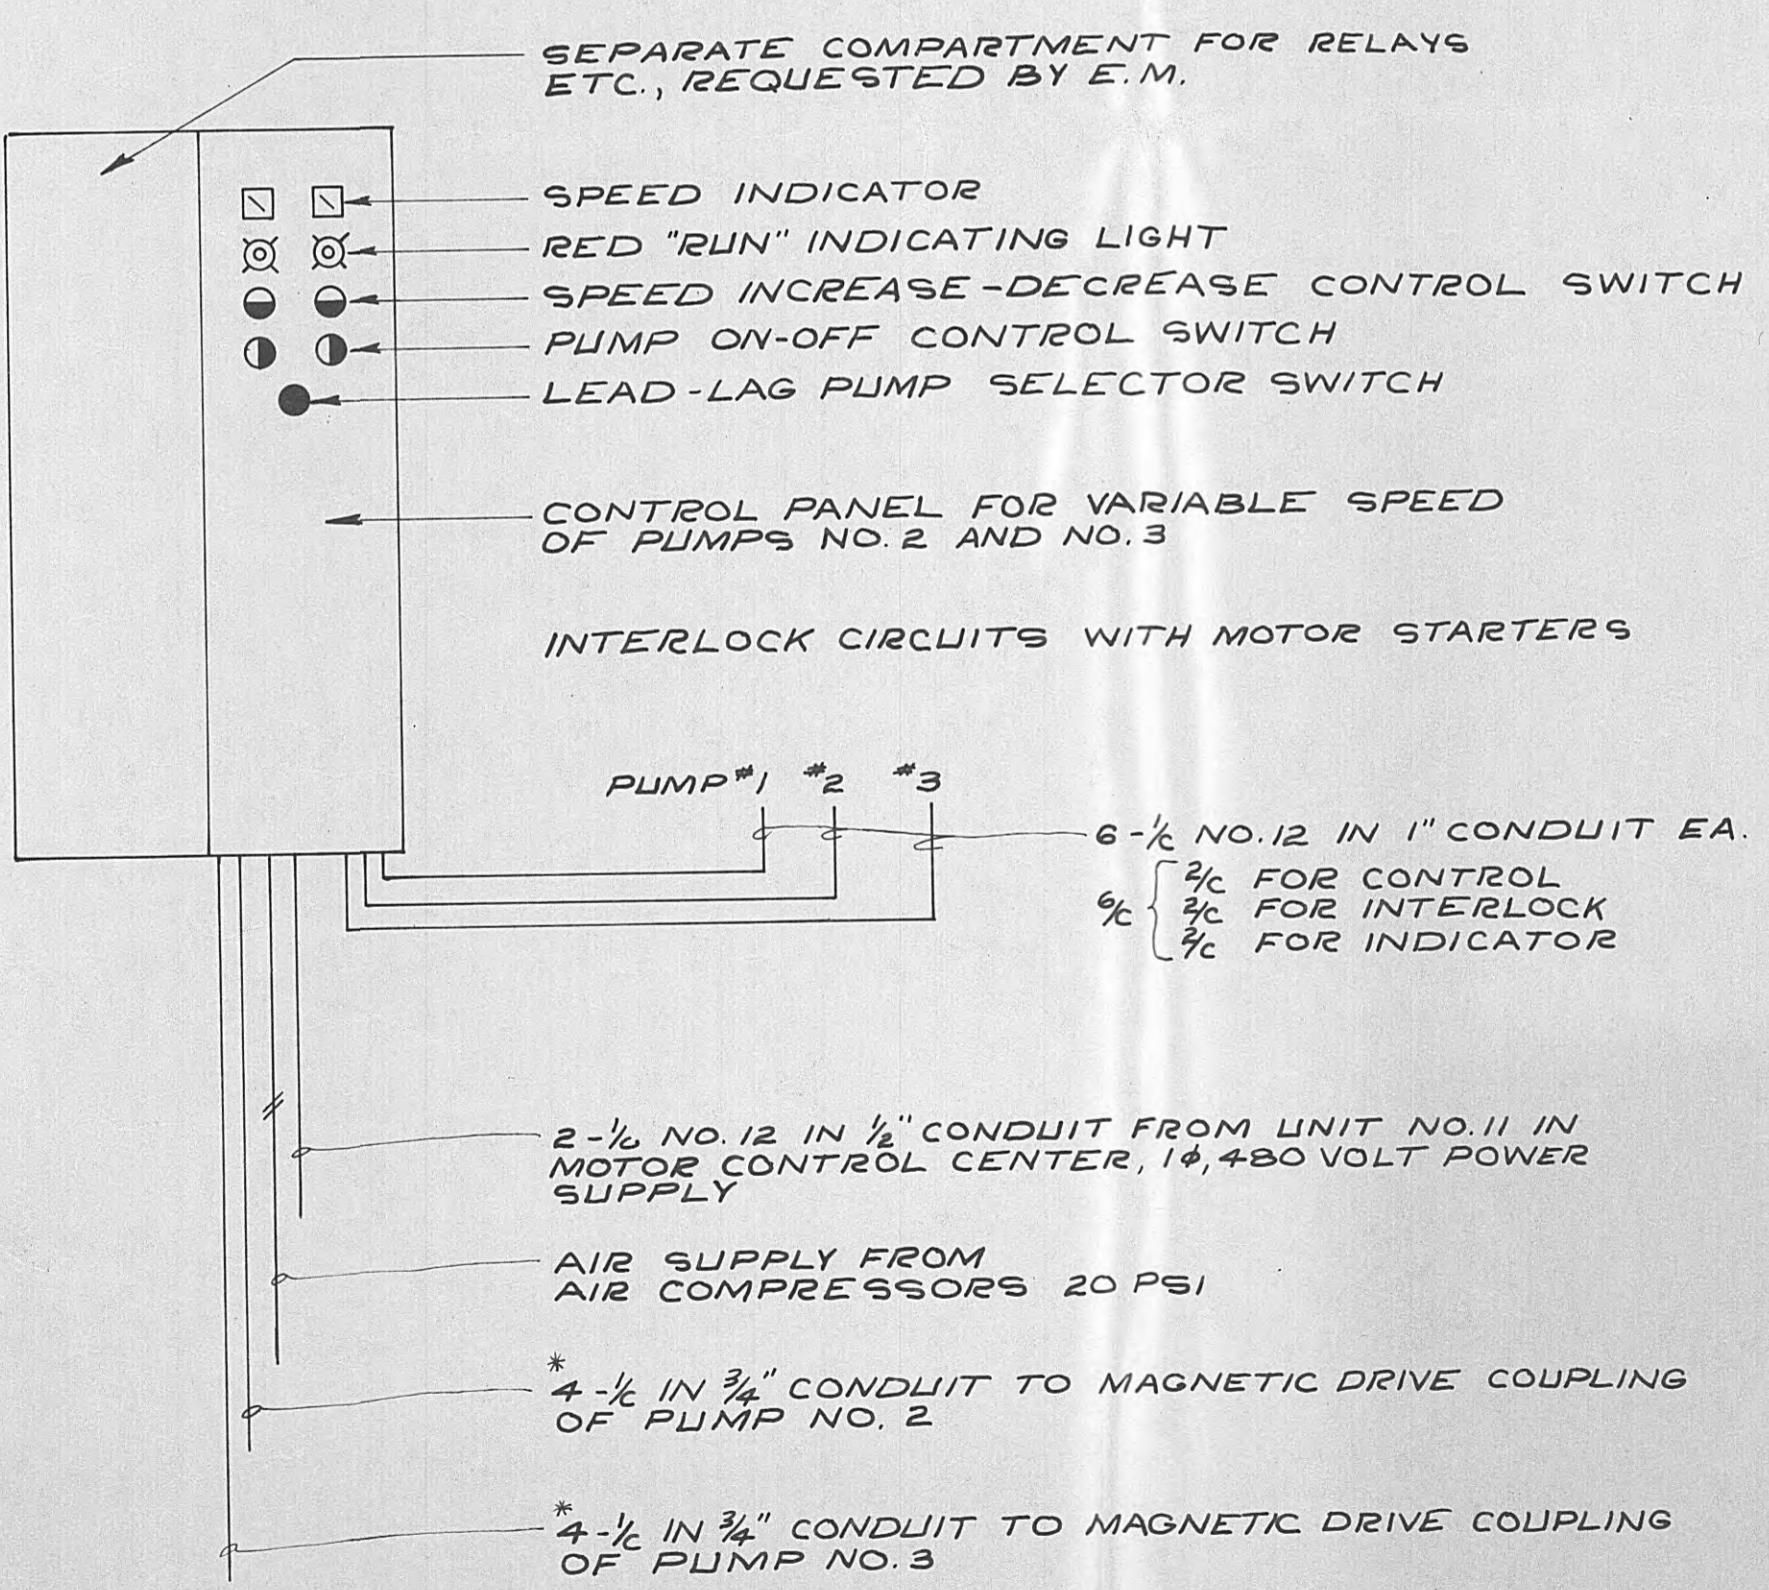

VARIABLE SPEED CONTROL PANEL DETAIL

SCALE NONE

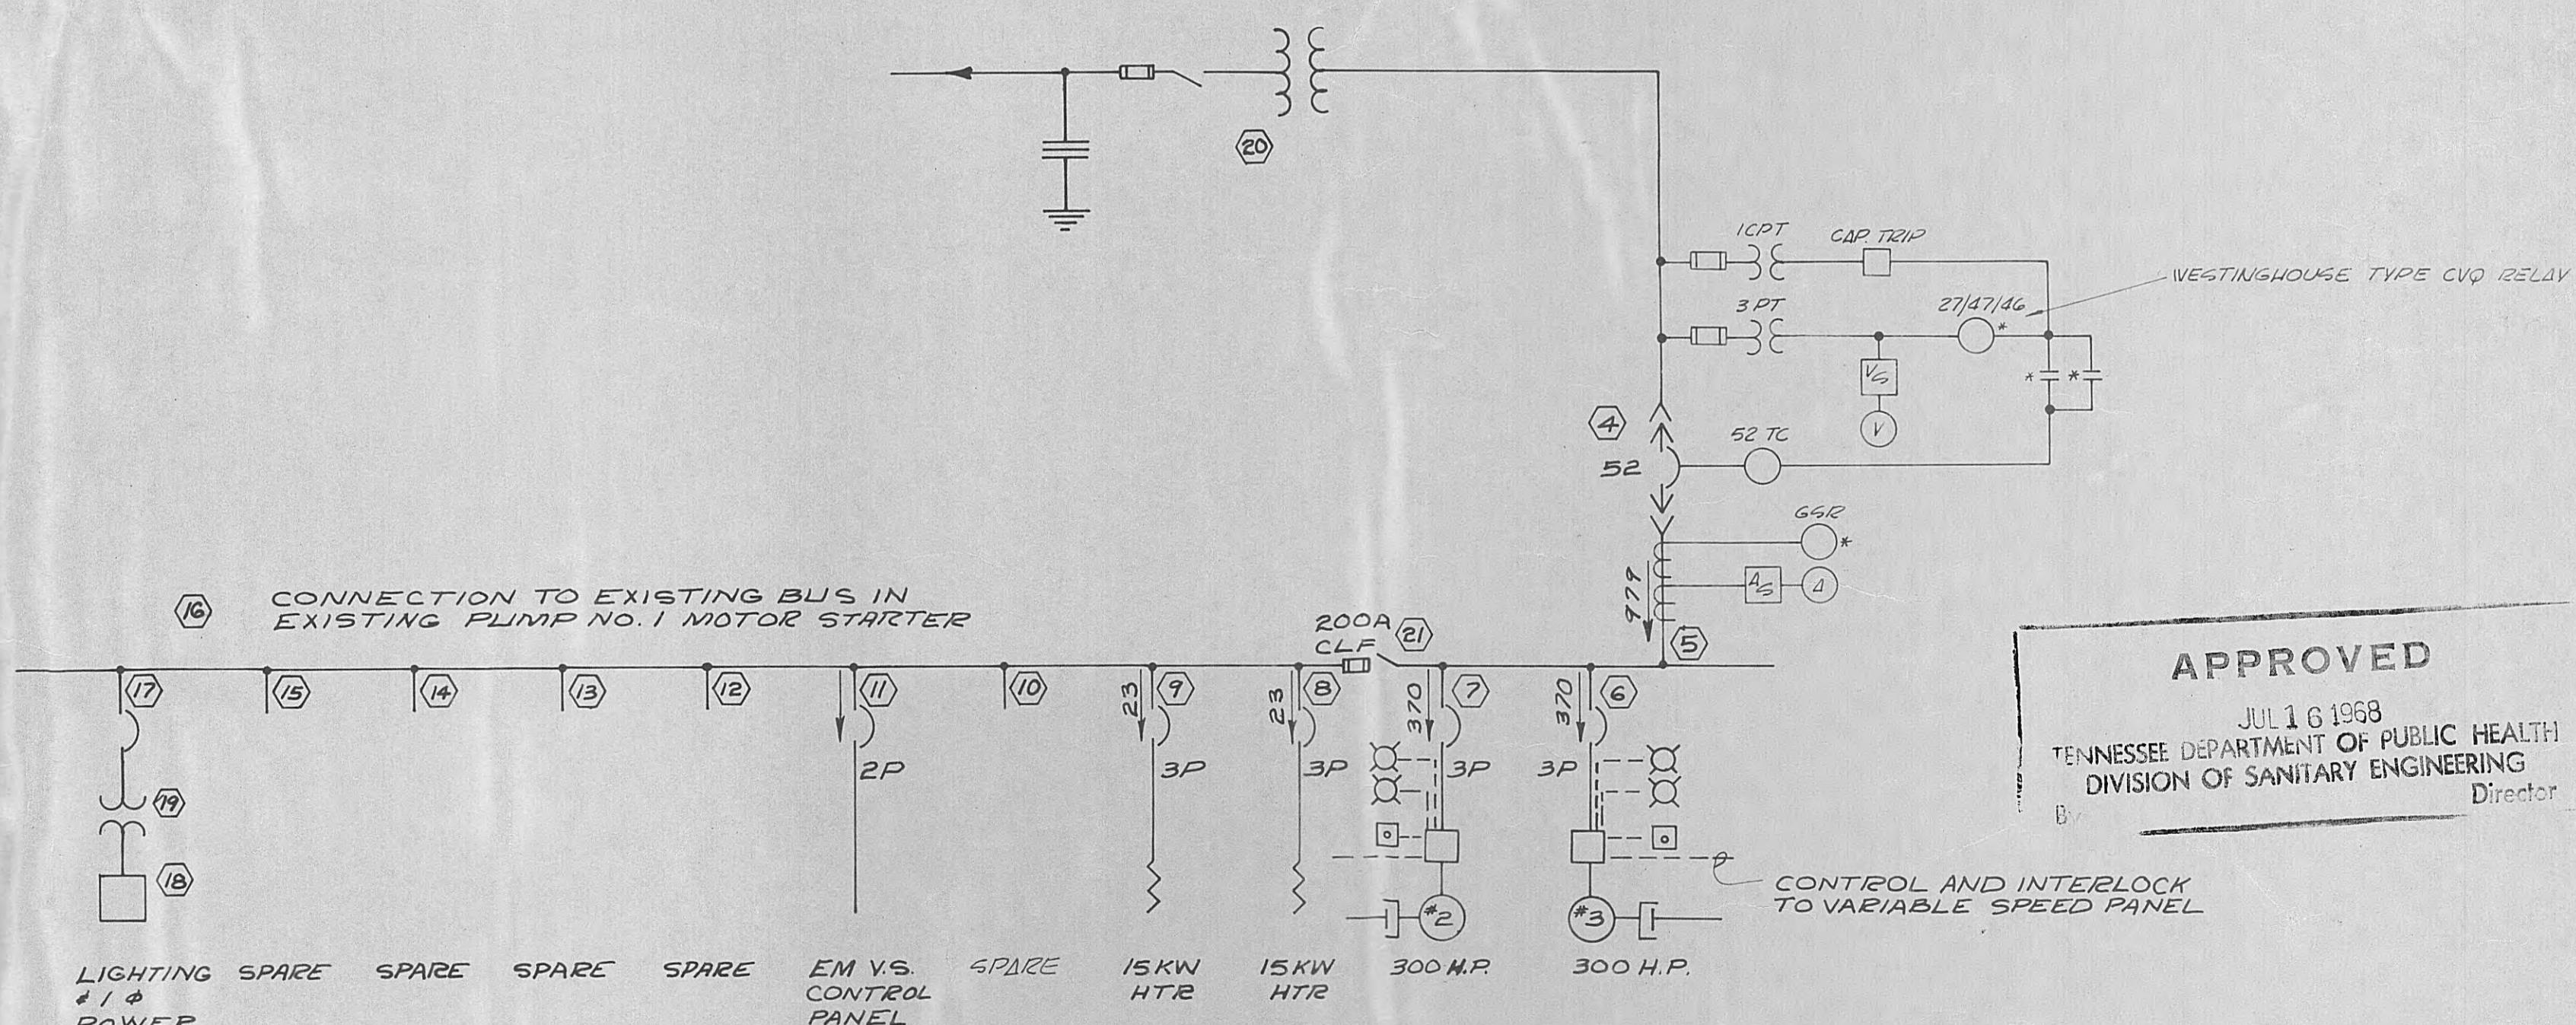


SCHEMATIC DIAGRAM

SCALE NONE

APPROVED
JUL 16 1968
TENNESSEE DEPARTMENT OF PUBLIC HEALTH
DIVISION OF SANITARY ENGINEERING
Director


PHASE II OF		
MODIFICATIONS TO EFFLUENT PUMPING SYSTEM FOR CITY OF HARRIMAN TENNESSEE		
ROANE COUNTY TENNESSEE		
BLACK, CROW AND EIDSNESS, INC. ENGINEERS		
GAINESVILLE FLORIDA		
DRAWN BY: ROE	DATE:	FILE NO. 479-68-2
CHECKED BY:		
SCALE: AS NOTED		
ELECTRICAL DETAILS		
SHEET NO. E-2		

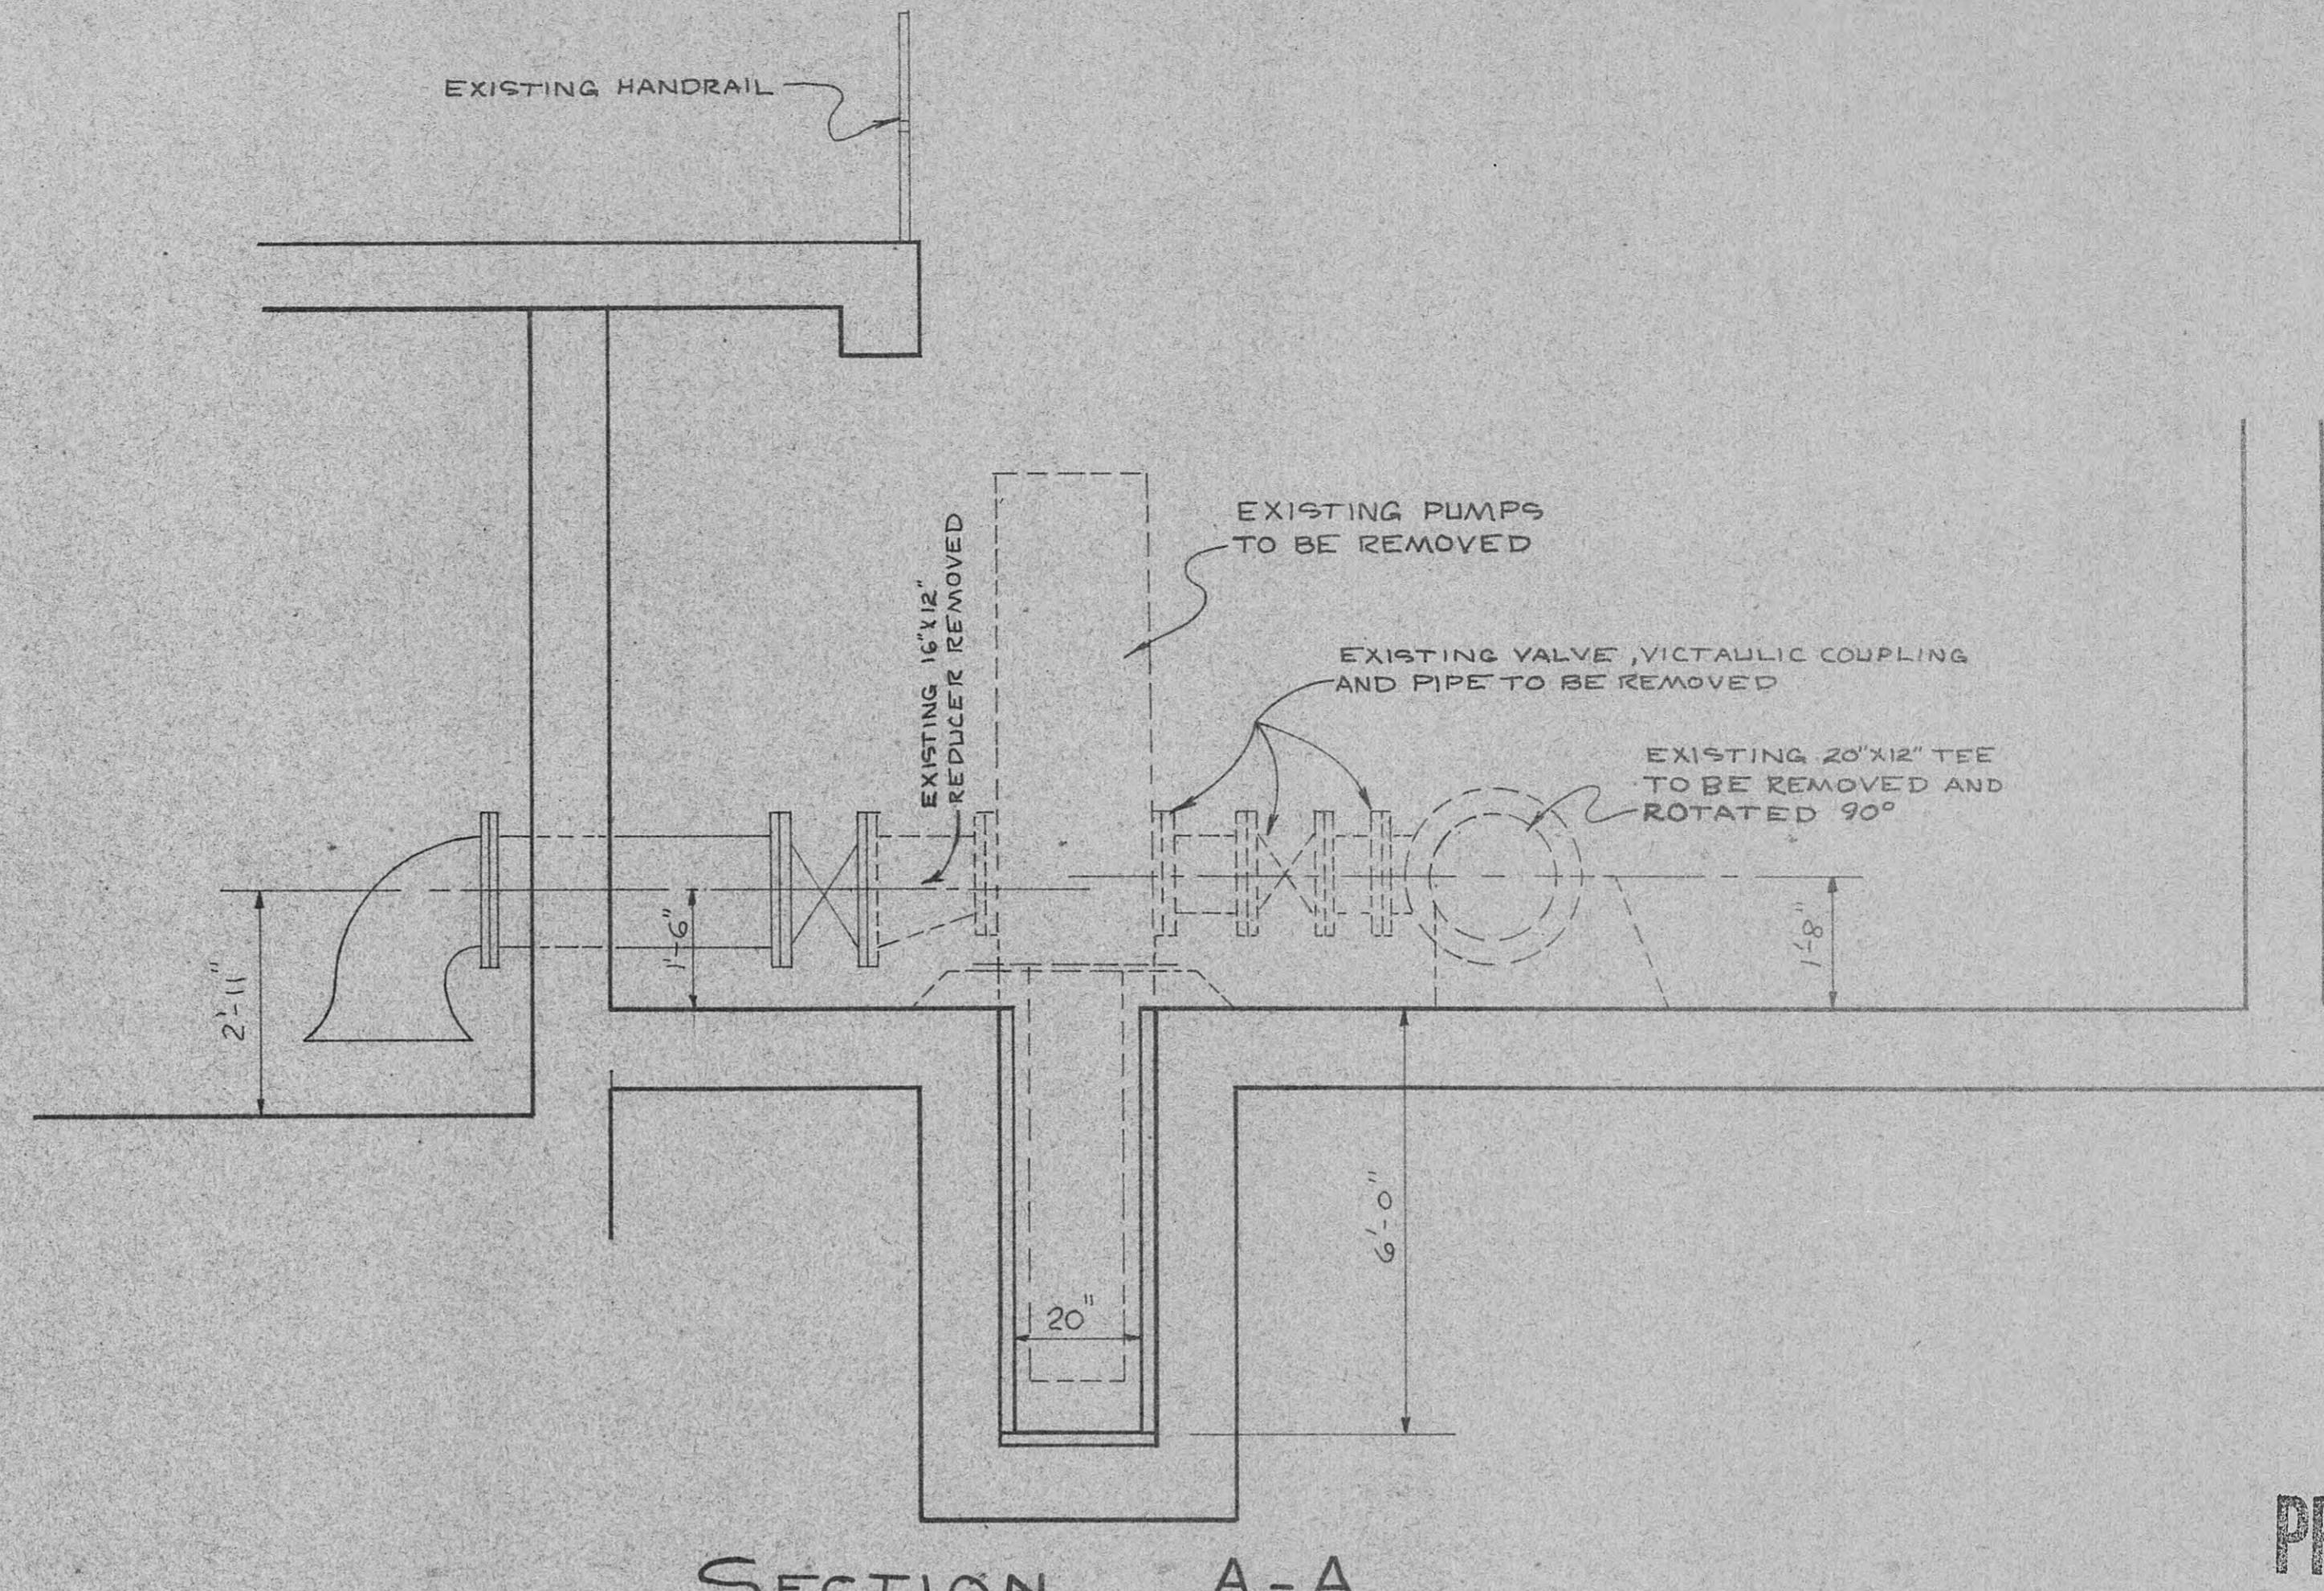

SECTION A-A


SCALE $\frac{1}{2}''=1'-0''$

PRELIMINARY
NOT FOR CONSTRUCTION

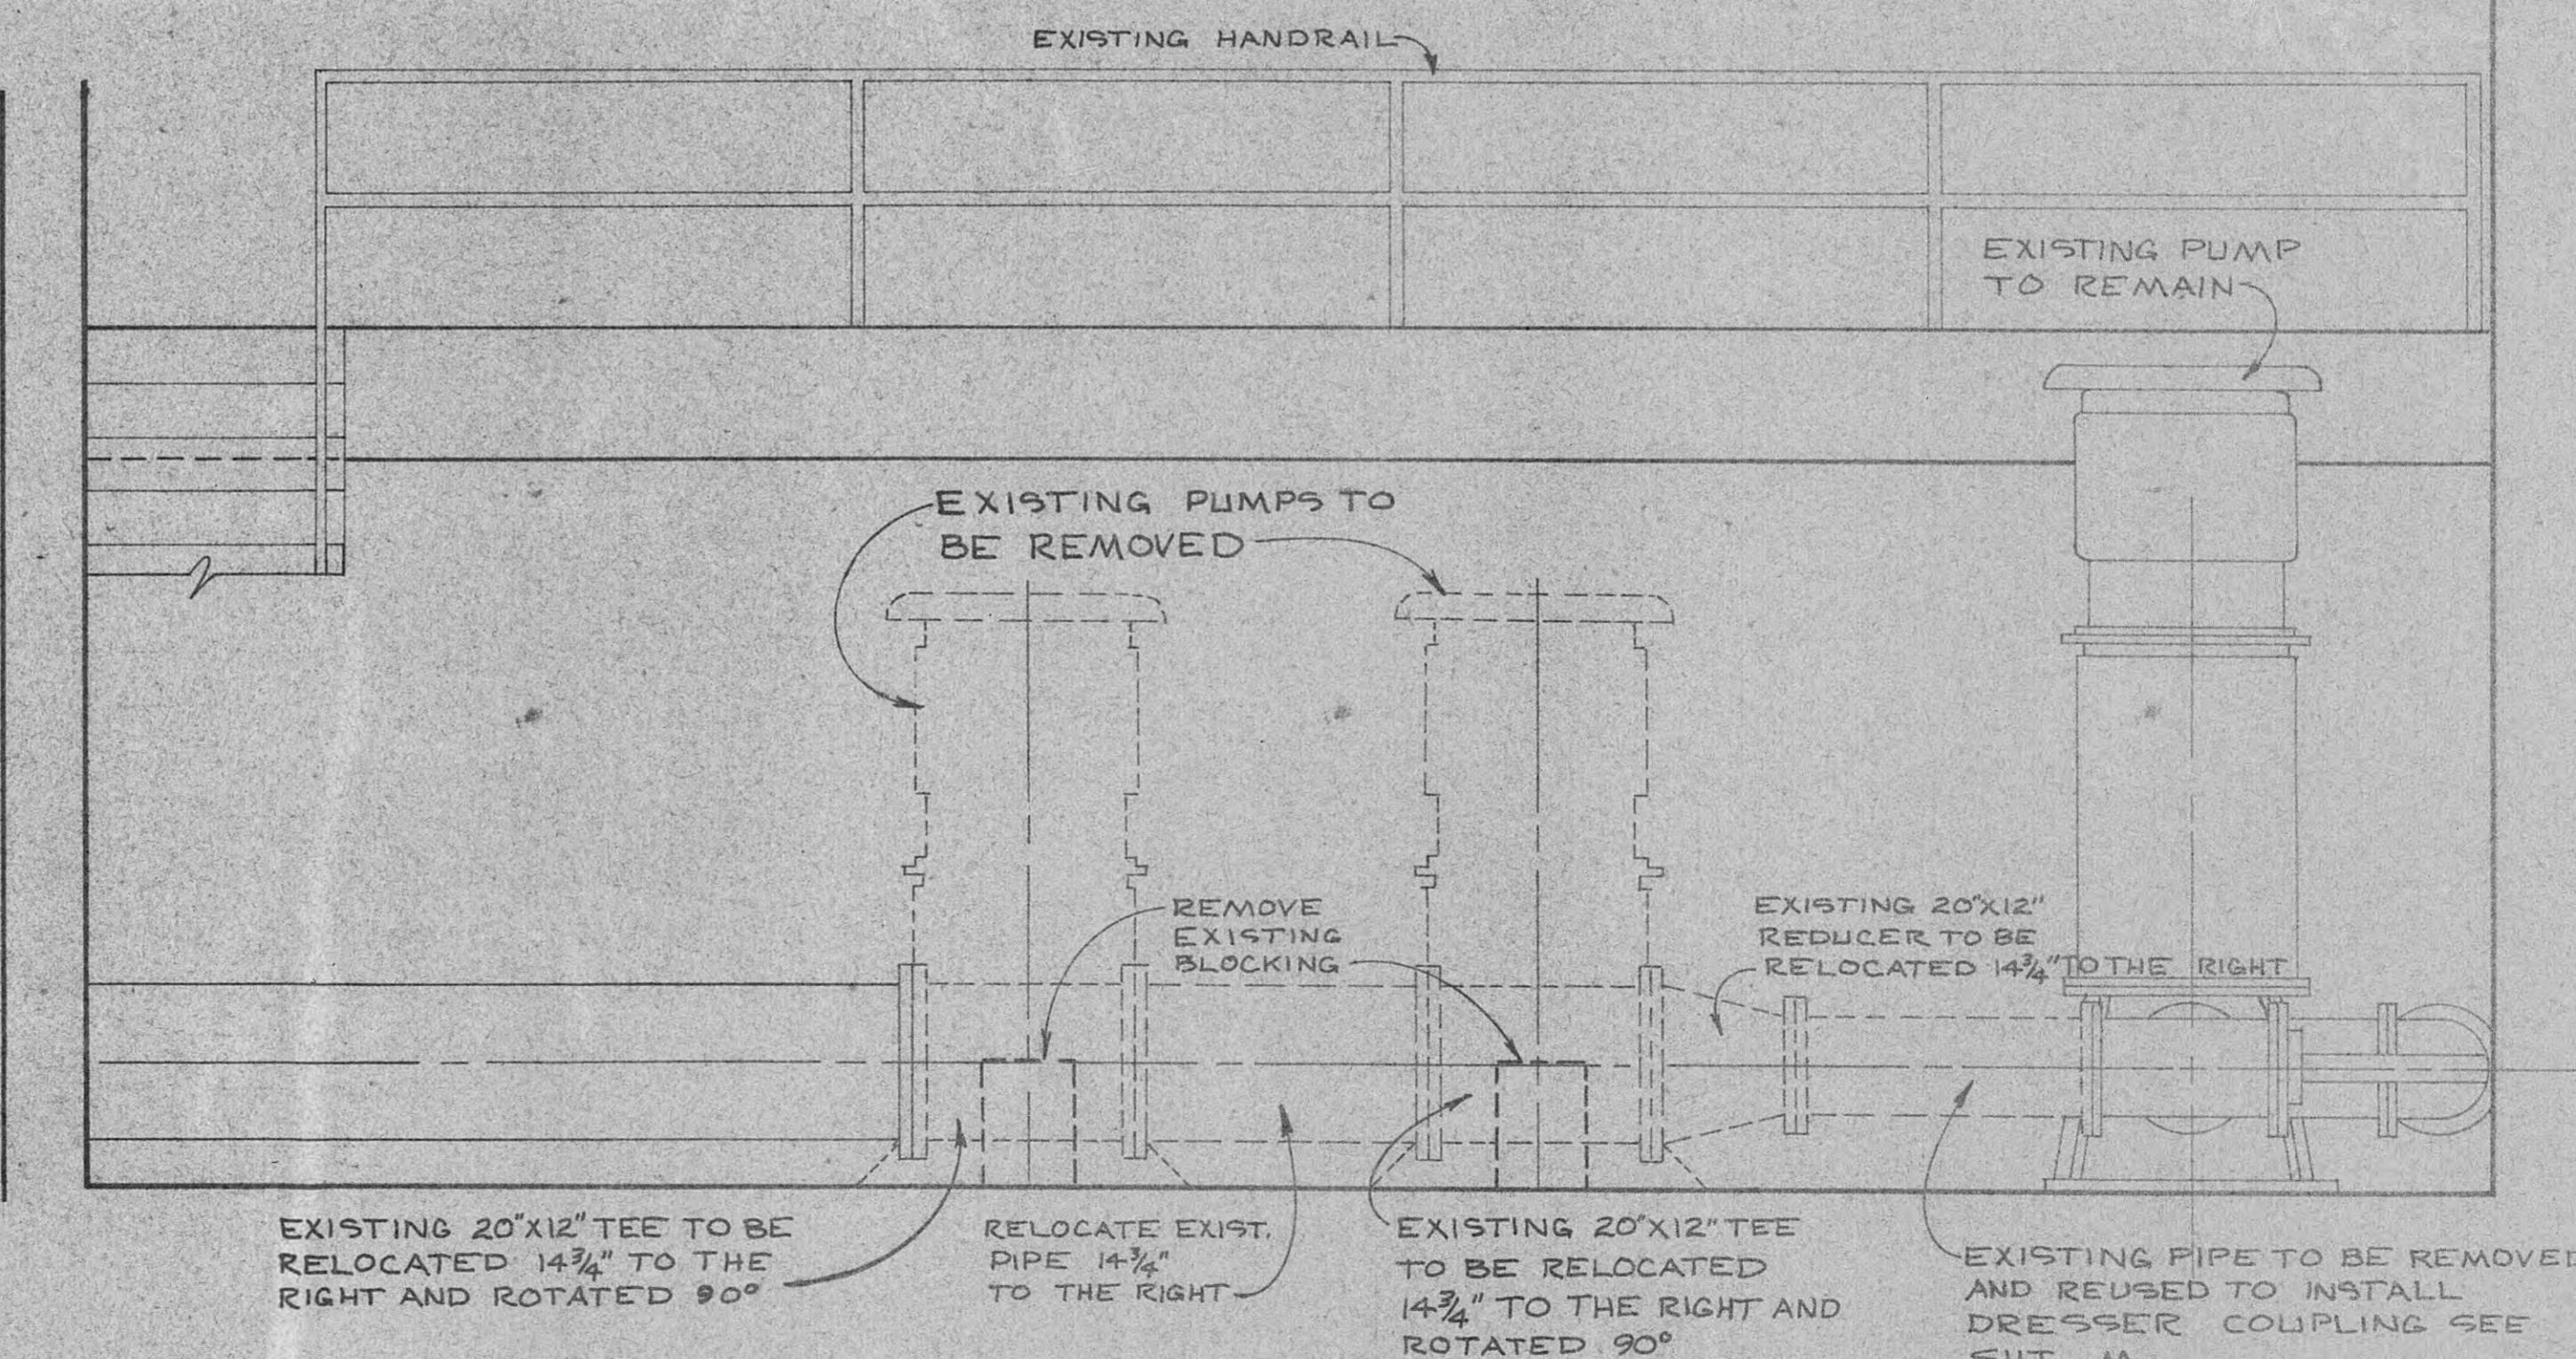

SECTION B-B

SCALE $\frac{1}{2}''=1'-0''$

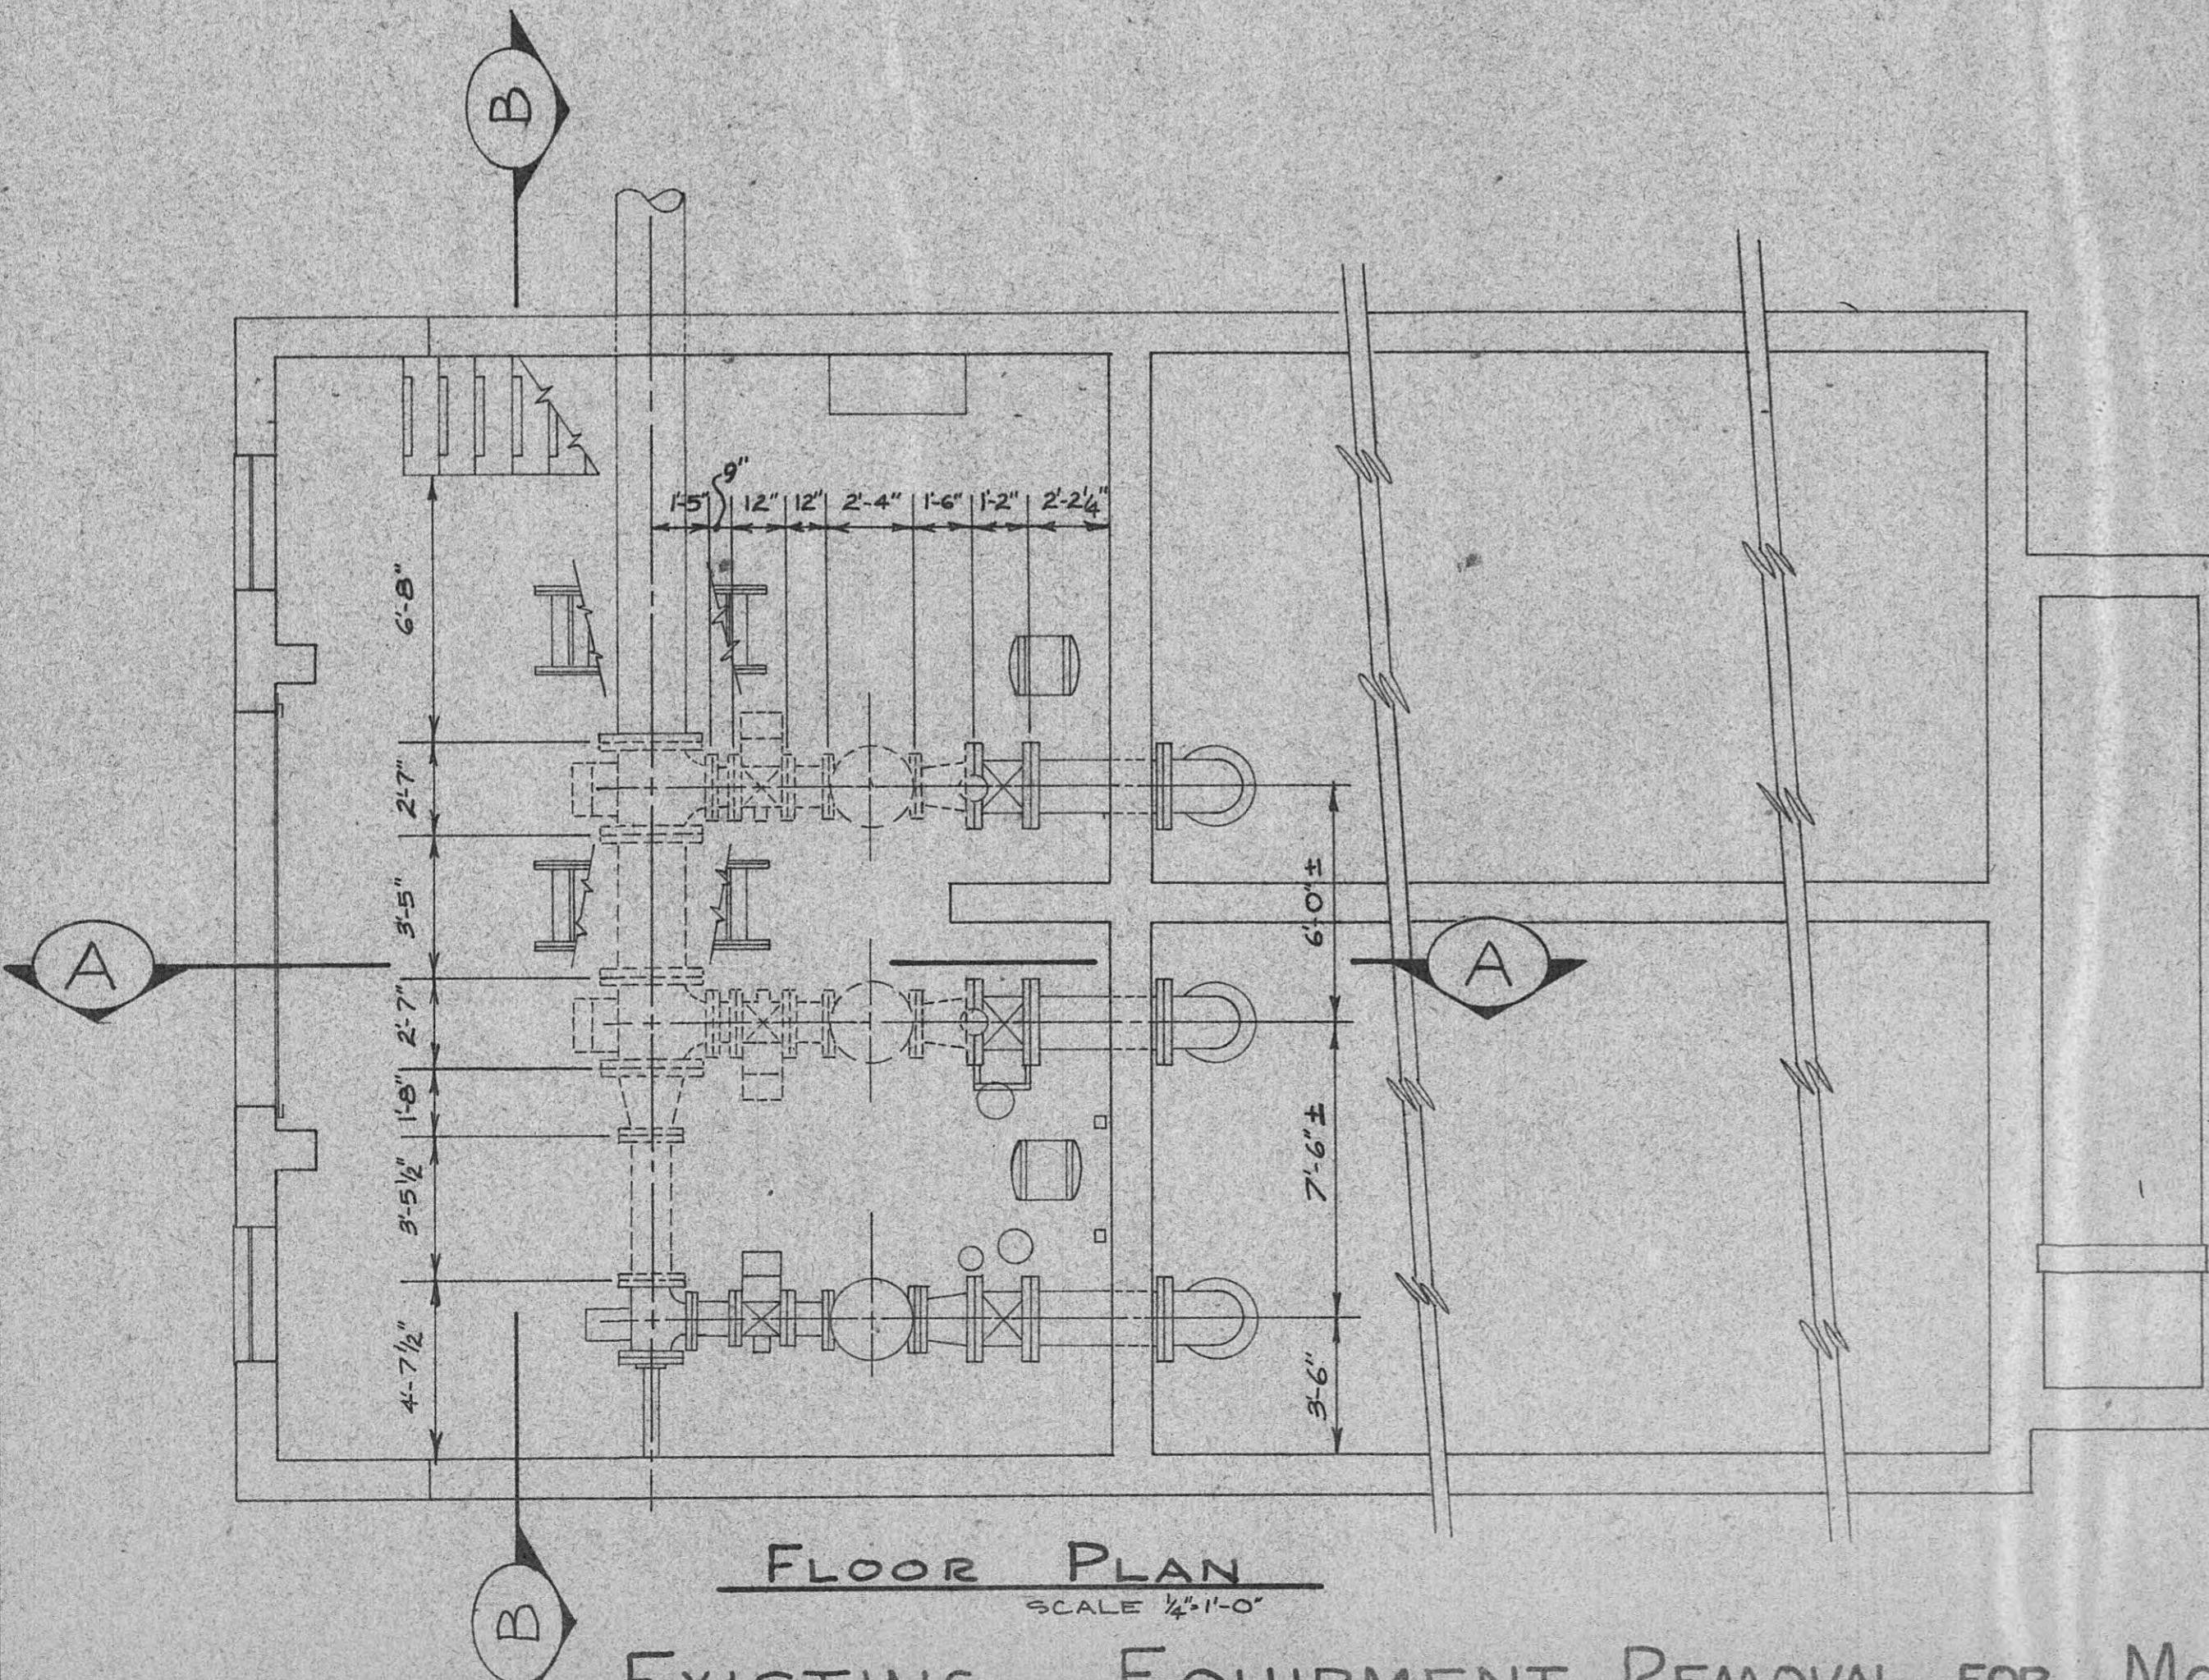

FLOOR PLAN

SCALE $\frac{1}{2}''=1'-0''$

EXISTING EQUIPMENT REMOVAL FOR MODIFICATIONS TO EXISTING PUMP STATION #3

MODIFICATIONS TO EFFLUENT PUMPING SYSTEM FOR CITY OF HARRIMAN TENNESSEE ROANE COUNTY TENNESSEE								
BLACK, CROW AND EIDSNESS, INC. ENGINEERS GAINESVILLE FLORIDA								
DRAWN BY:	DATE:	FILE NO.:						
CHECKED BY:								
SCALE:								
<table border="1"> <tr> <td>NO.</td> <td>DESCRIPTION</td> <td>DATE</td> </tr> <tr> <td colspan="3">REVISONS</td> </tr> </table>			NO.	DESCRIPTION	DATE	REVISONS		
NO.	DESCRIPTION	DATE						
REVISONS								
SHEET NO.:								

**SANITARY SEWERAGE
FACILITIES
FOR
CITY OF
HARRIMAN, TENNESSEE**



BLACK CROW AND EIDSNESS, INC.

ENGINEERS

GAINESVILLE, FLORIDA
CLEARWATER, BOCA RATON, NAPLES, FLORIDA
ATLANTA, GEORGIA SAN JOSE, COSTA RICA

PRELIMINARY
NOT FOR CONSTRUCTION
MODIFICATIONS TO
EFFLUENT PUMPING SYSTEM
PROJECT NO. 479-67-1

