

**PILOT WASTEWATER TREATMENT PLANT
FOR
HARRIMAN UTILITY BOARD**

BLACK, CROW AND EIDSNESS, INC.
ATLANTA — GAINESVILLE — ENGINEERS — GEORGIA / FLORIDA


| | |
|------------------------------------|-------------------------------------|
| DRAWN BY TAE, RM CHECKED BY TDR | DATE: JUNE '63 FILE NO.: 484-63- |
|------------------------------------|-------------------------------------|


SCALE: 1'-20'-0"

SEARCHED INDEXED SERIALIZED FILED
FEB 1 1968

OF 2

Digitized by srujanika@gmail.com

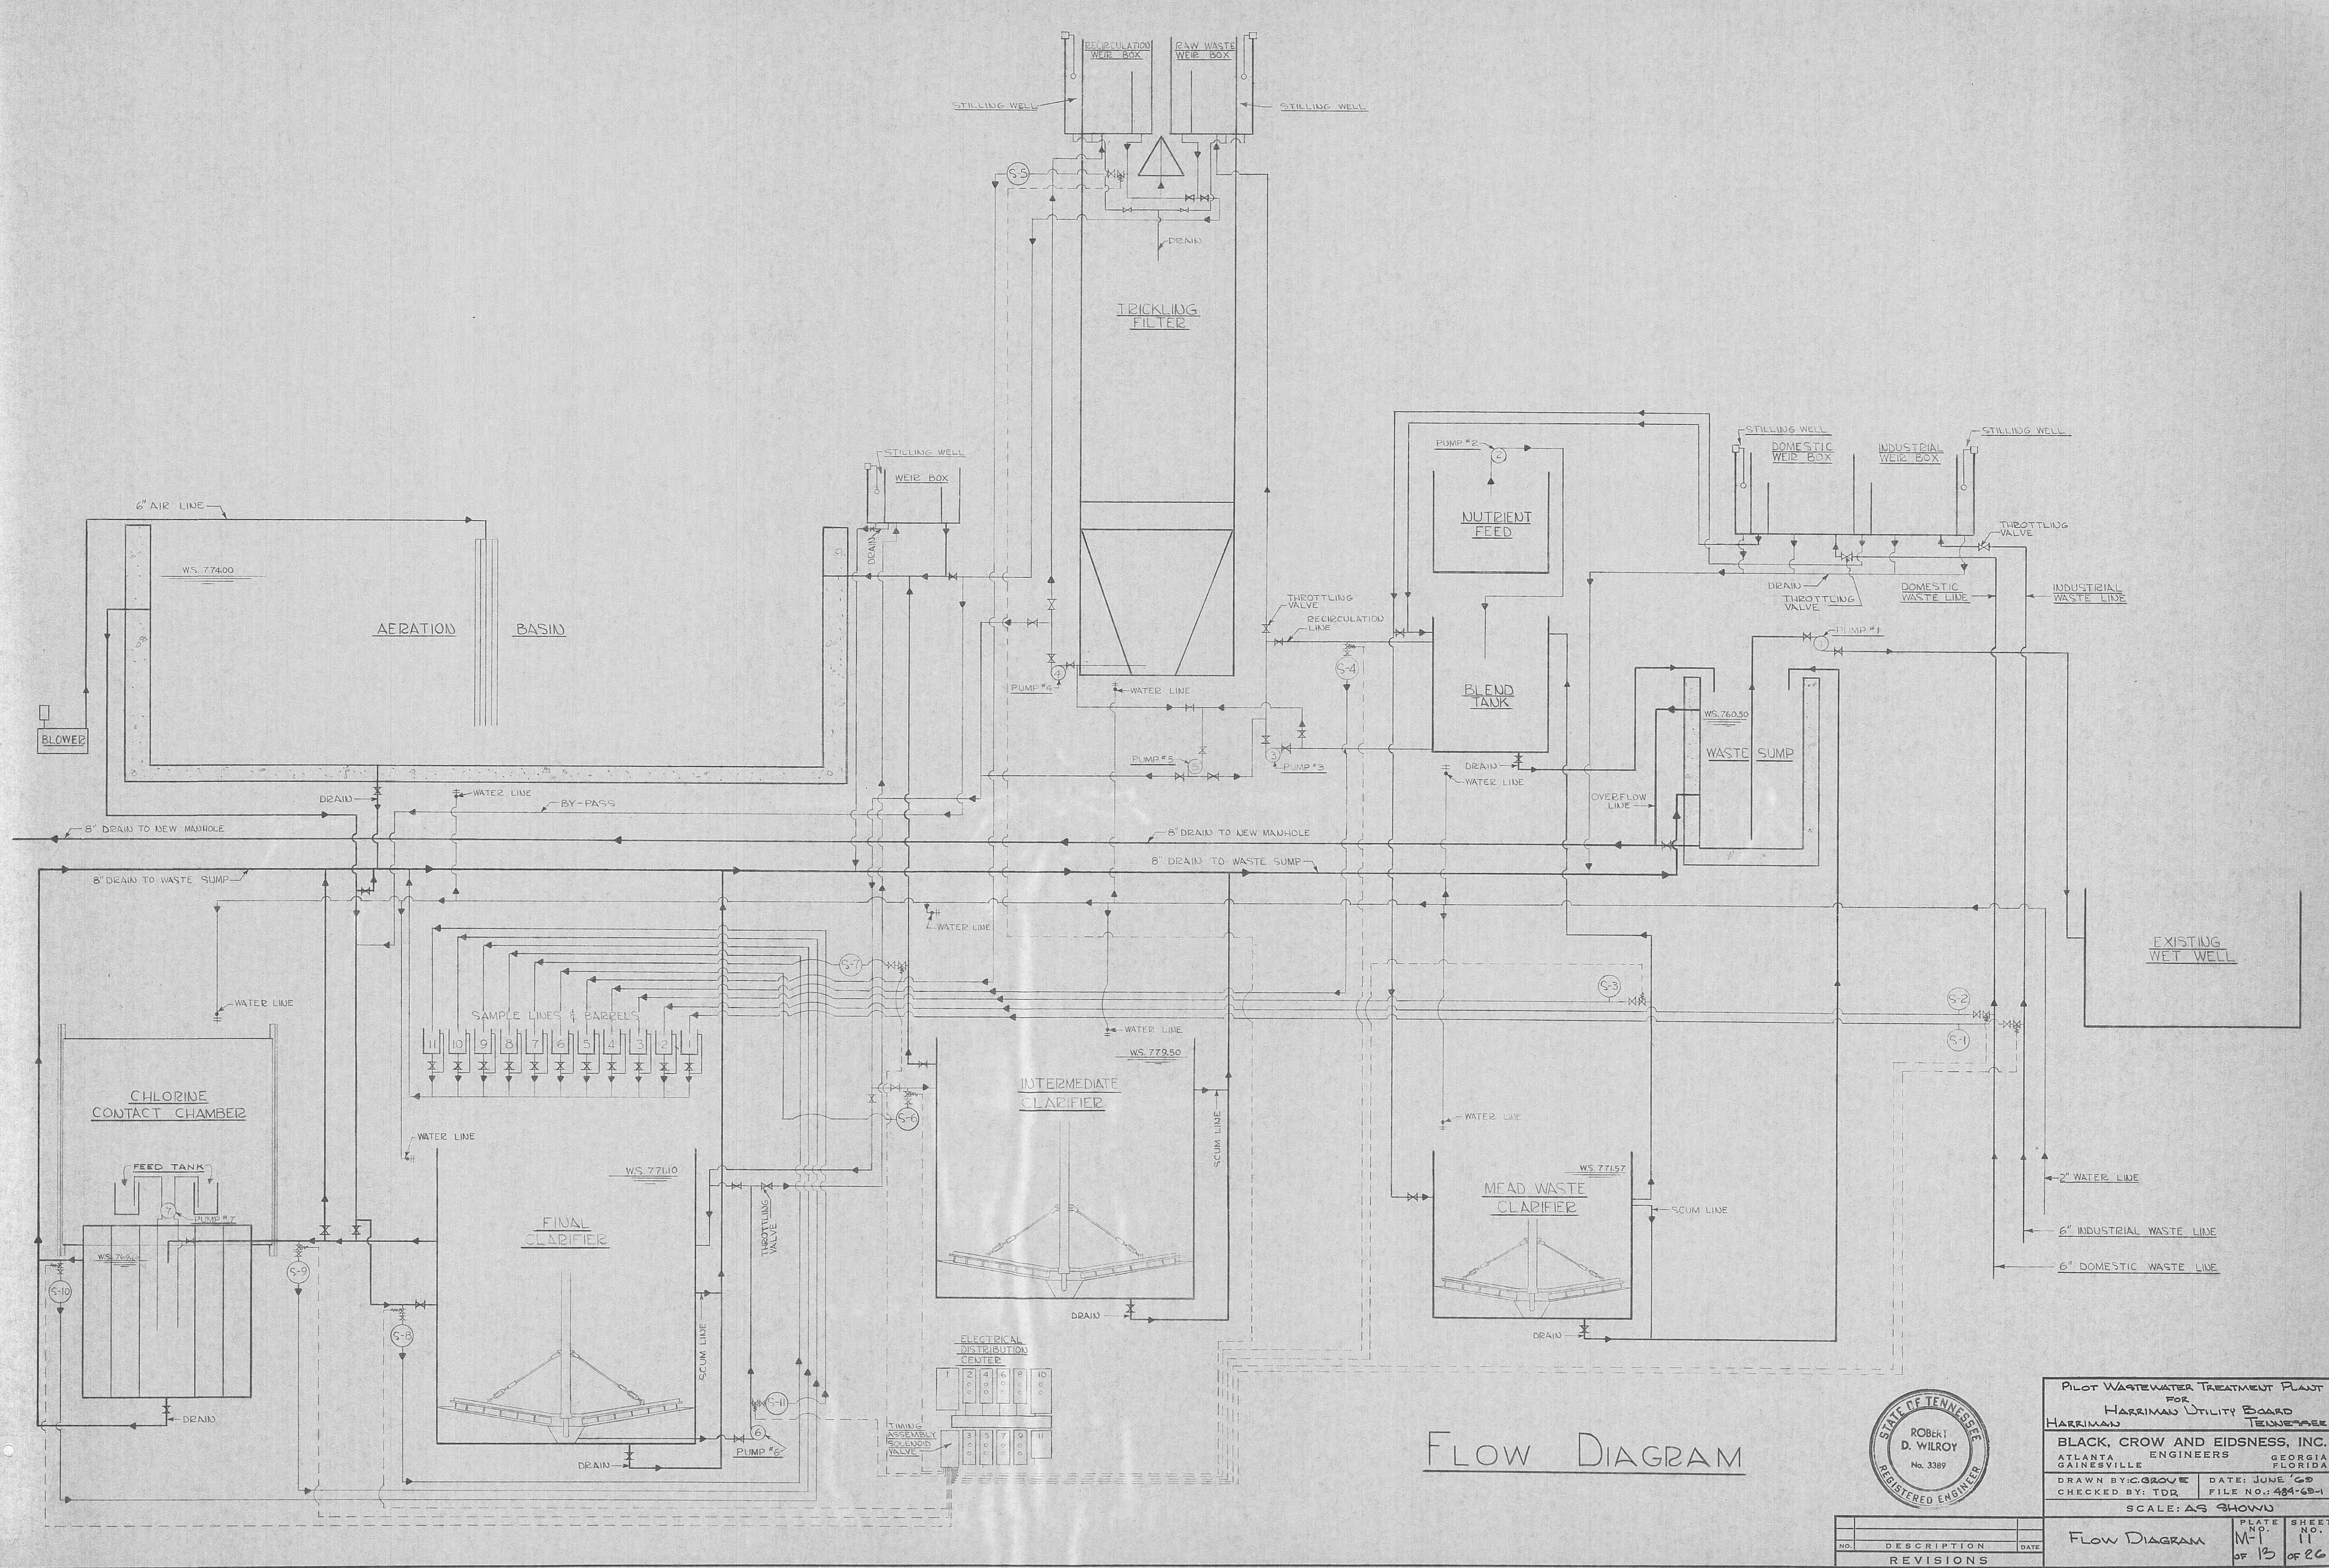


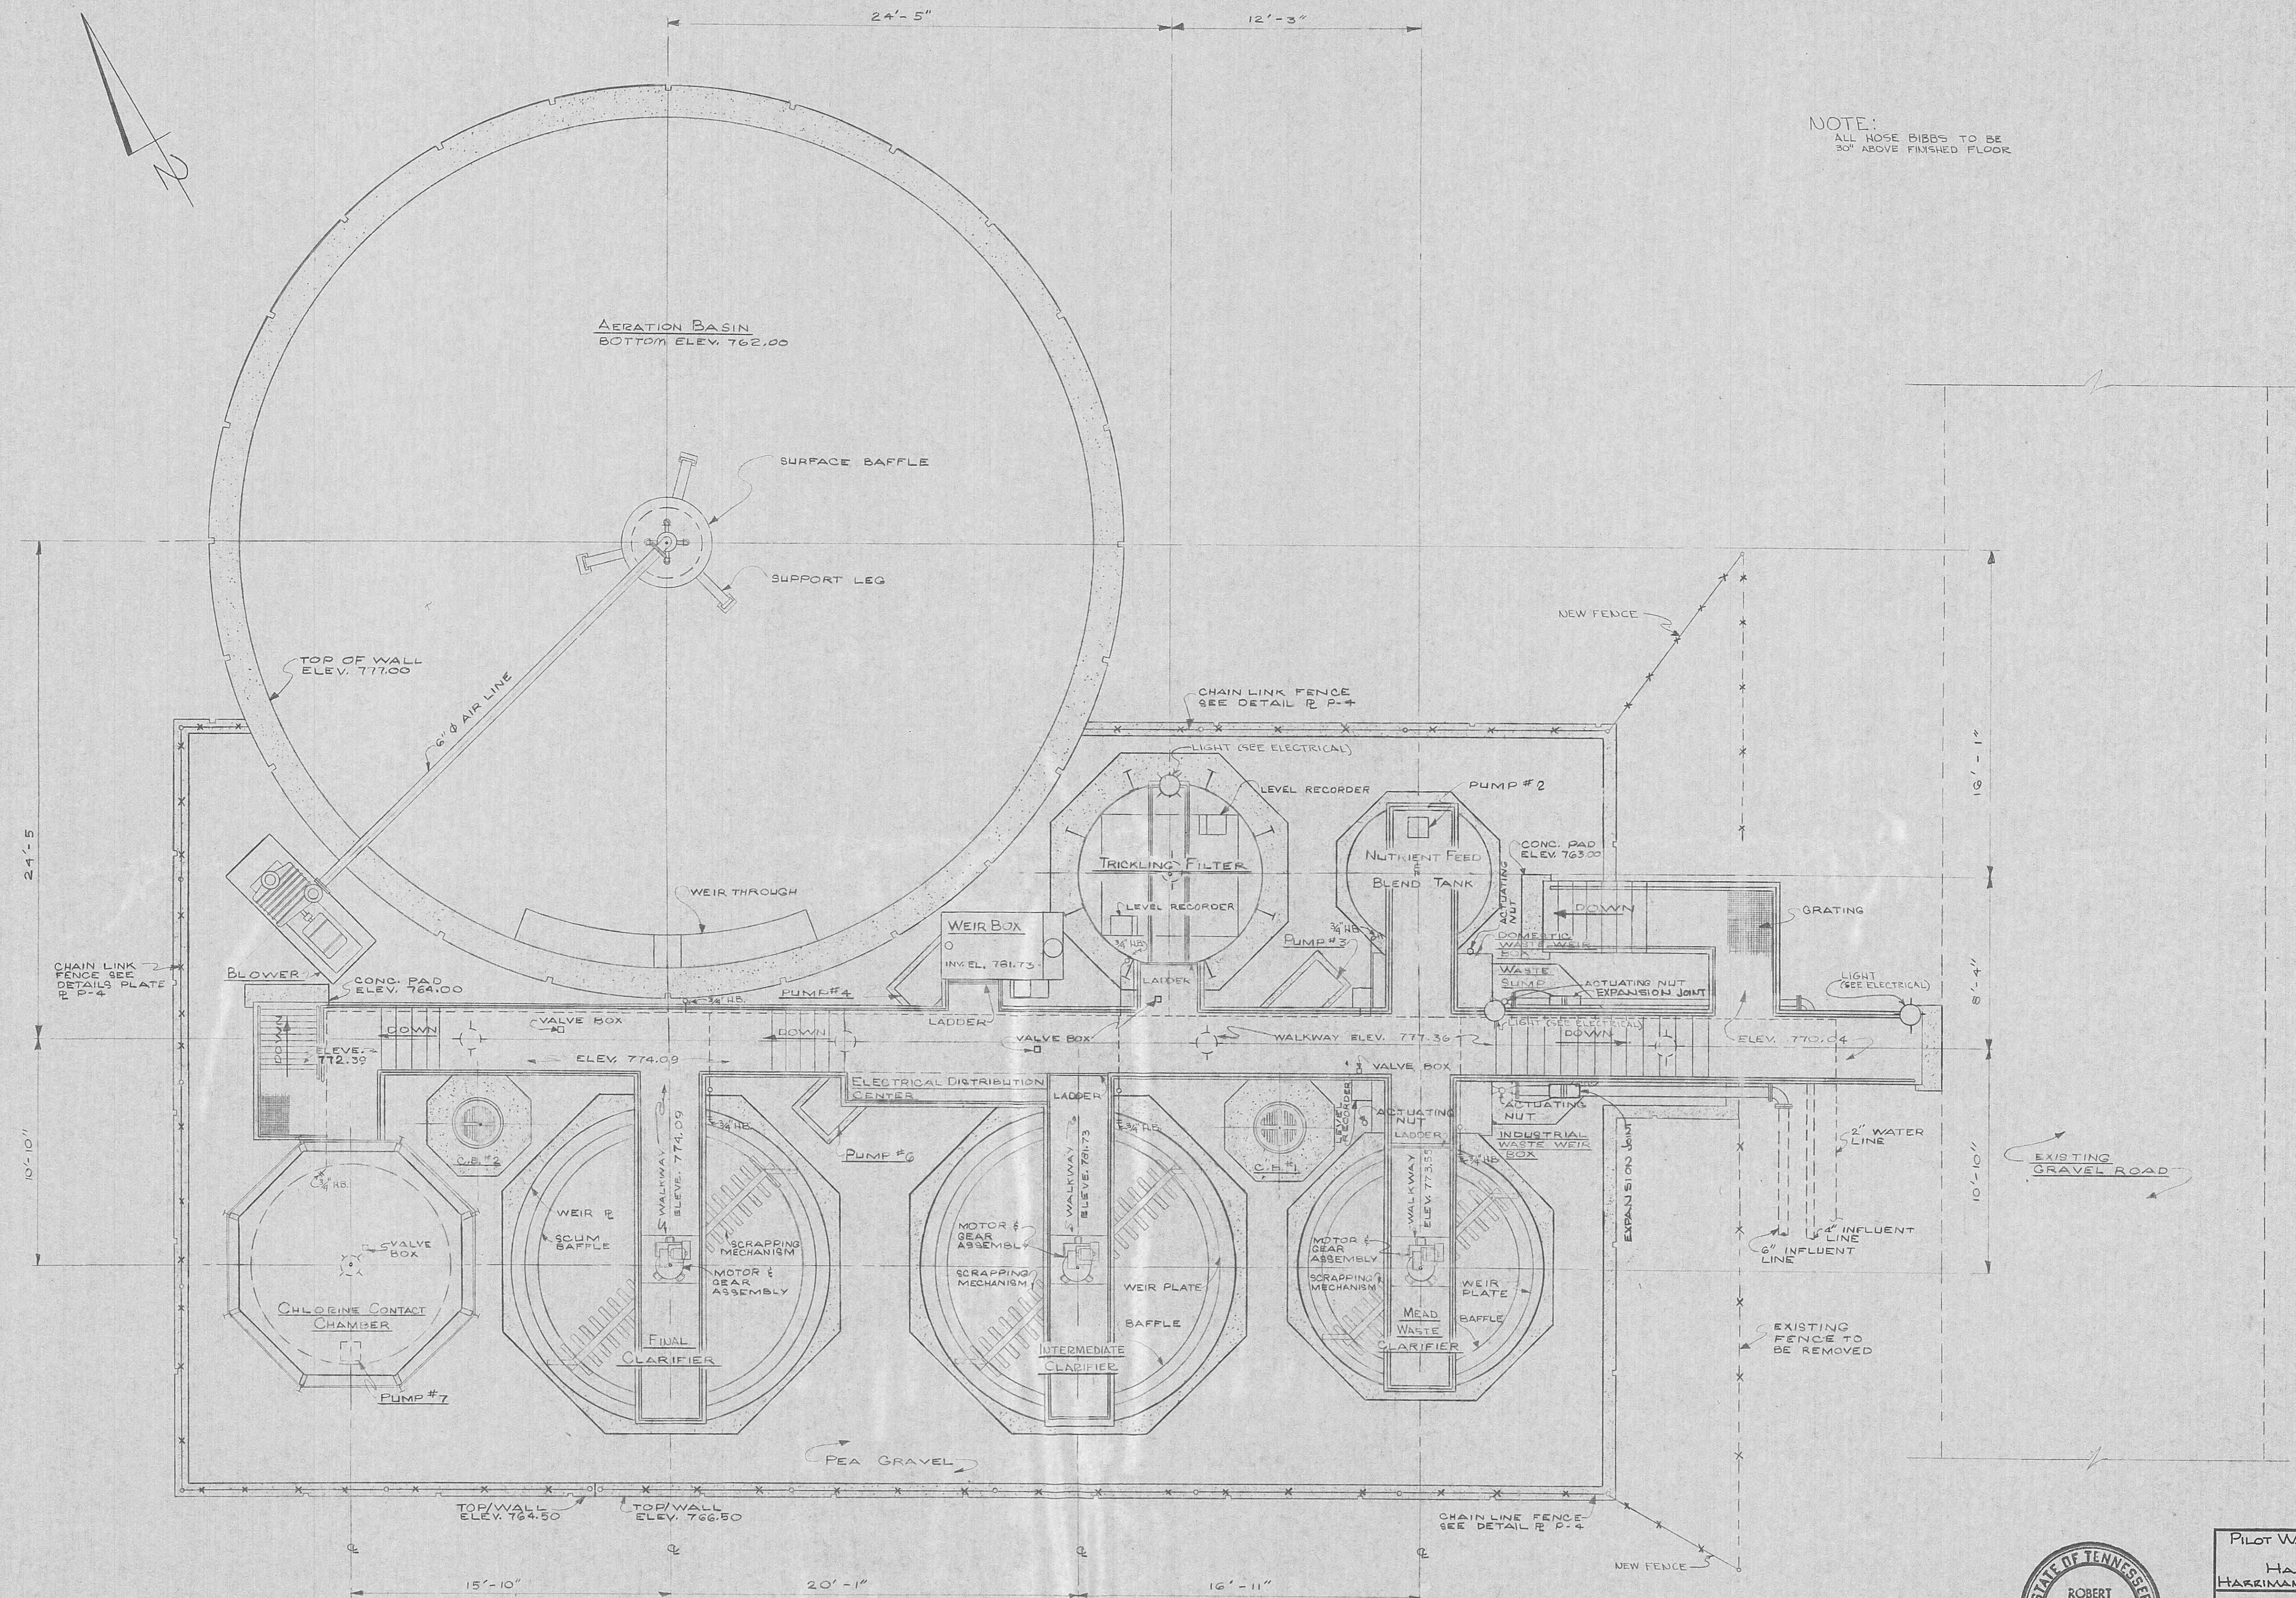

PLANT LAYOUT PLAN



SCALE:

1/4" = 1'-0"

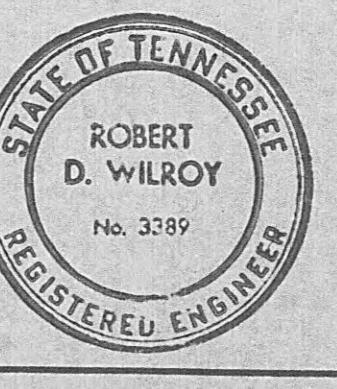



Pilot Wastewater Treatment Plant
FOR
HARRIMAN UTILITY BOARD
TENNESSEE
BLACK, CROW AND EIDSNESS, INC.
ATLANTA ENGINEERS GEORGIA
GAINESVILLE FLORIDA
DRAWN BY: BORELLA DATE: JULY '68
CHECKED BY: TDR FILE NO.: 484-60-1
SCALE: AS SHOWN

PLATE NO. M-2 SHEET NO. 12
OF 12 OF 26

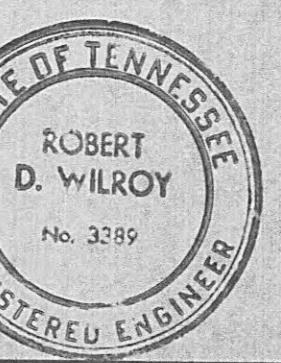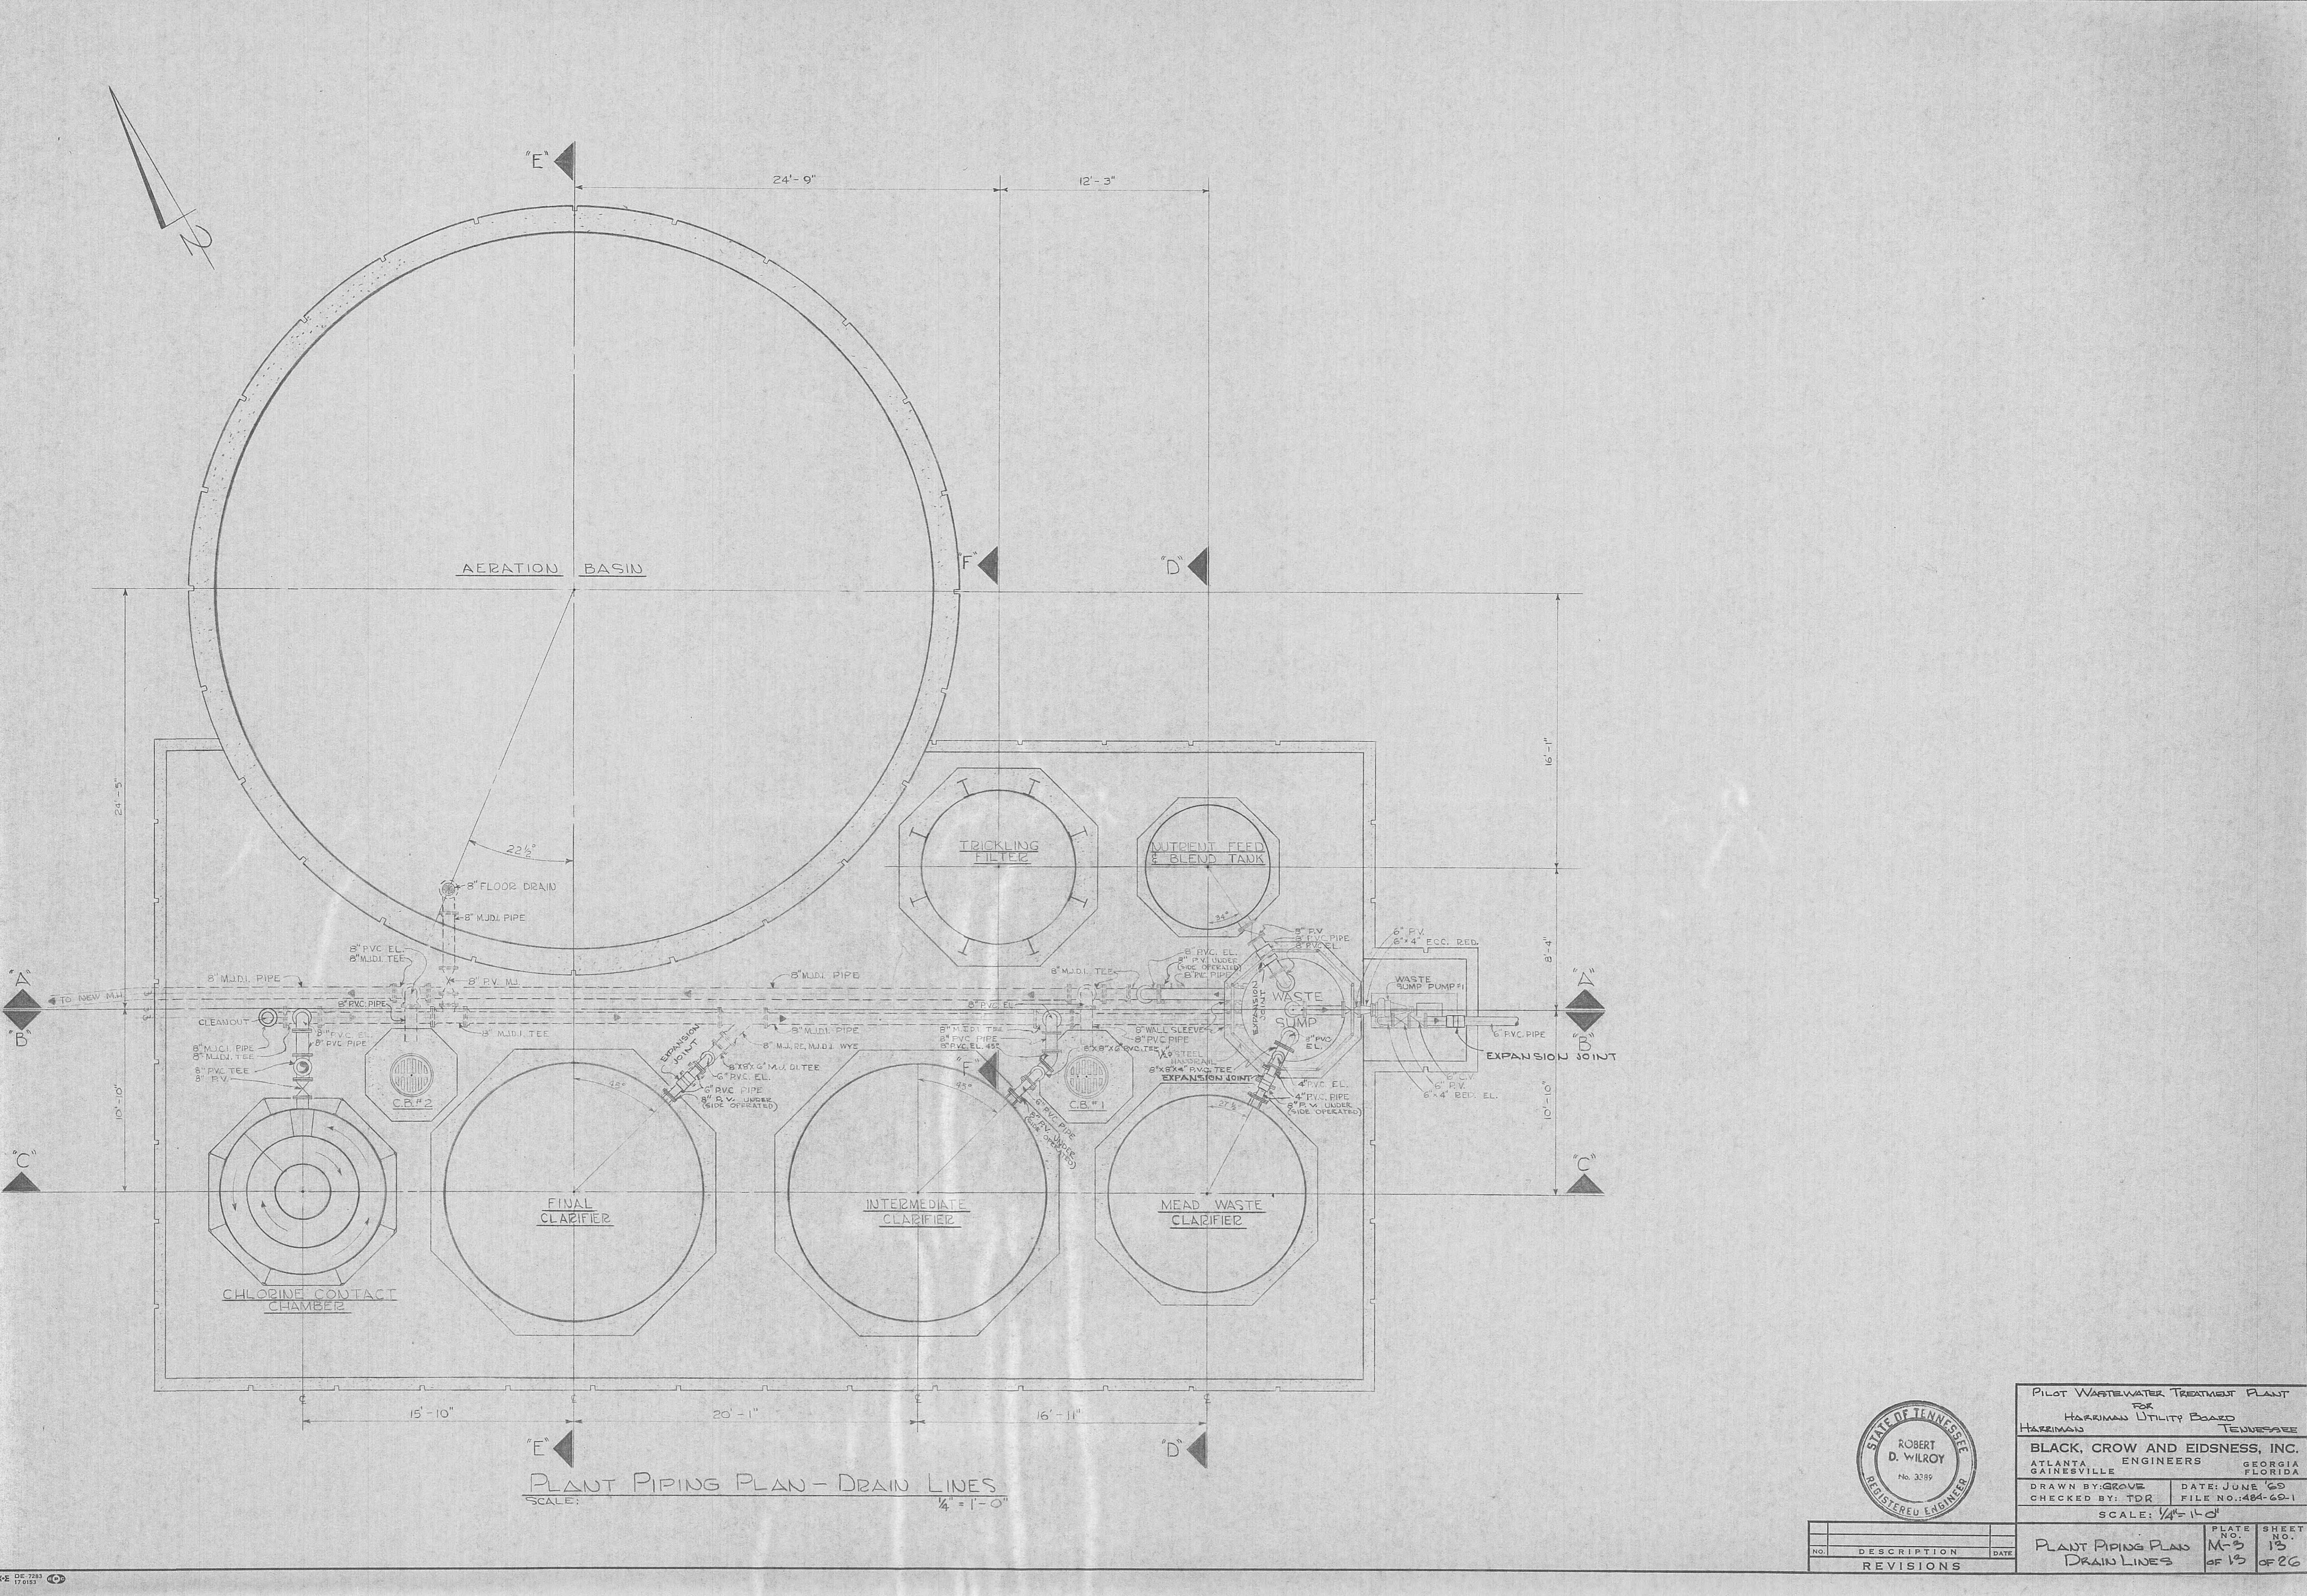


Pilot Wastewater Treatment Plant
FOR
HARRIMAN UTILITY BOARD
TENNESSEE
BLACK, CROW AND EIDNESS, INC.
ATLANTA, GEORGIA
GAINESVILLE, FLORIDA
DRAWN BY: GROVE
CHECKED BY: TDR
DATE: JUNE '69
FILE NO.: 484-69-1
REGISTERED ENGINEER
NO. 3289


PLATE NO. M-3
SHEET NO. 13
OF 15
OF 26
SCALE: $\frac{1}{4}'' = 1'-0''$

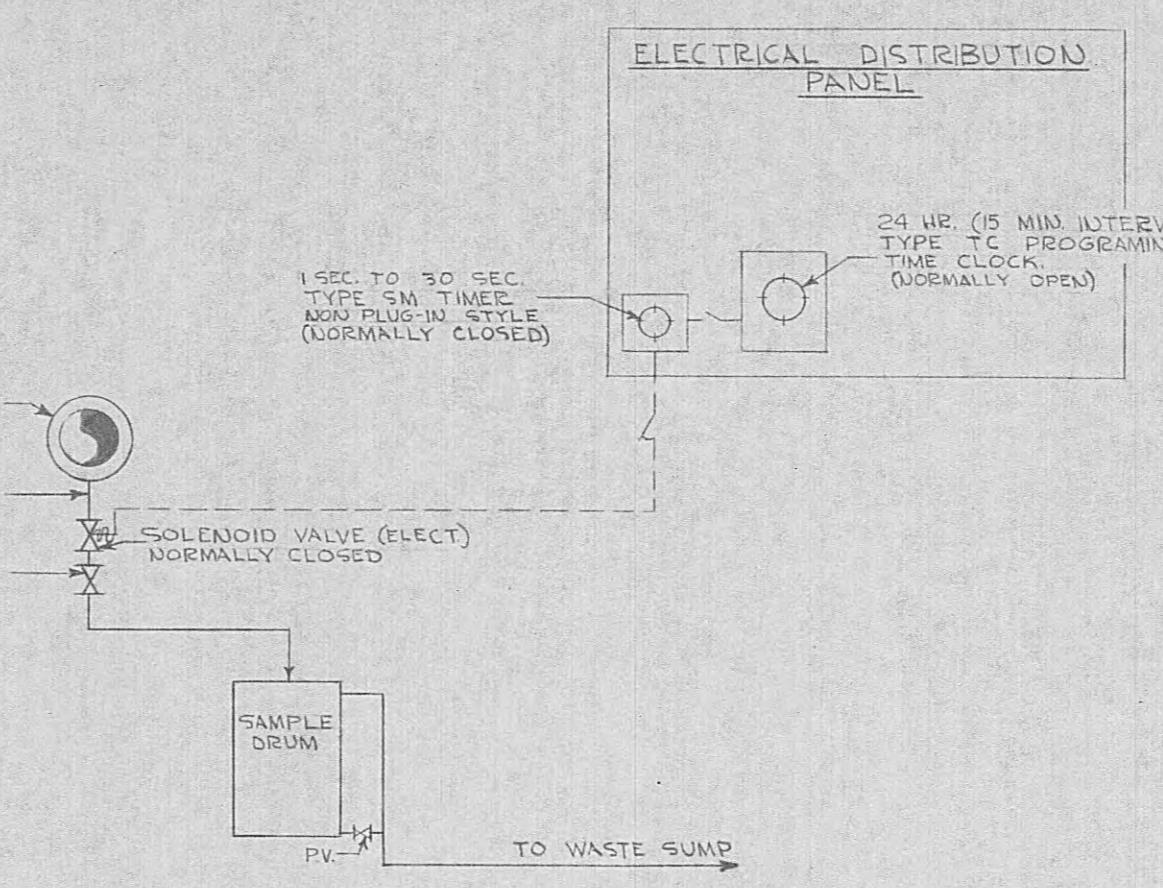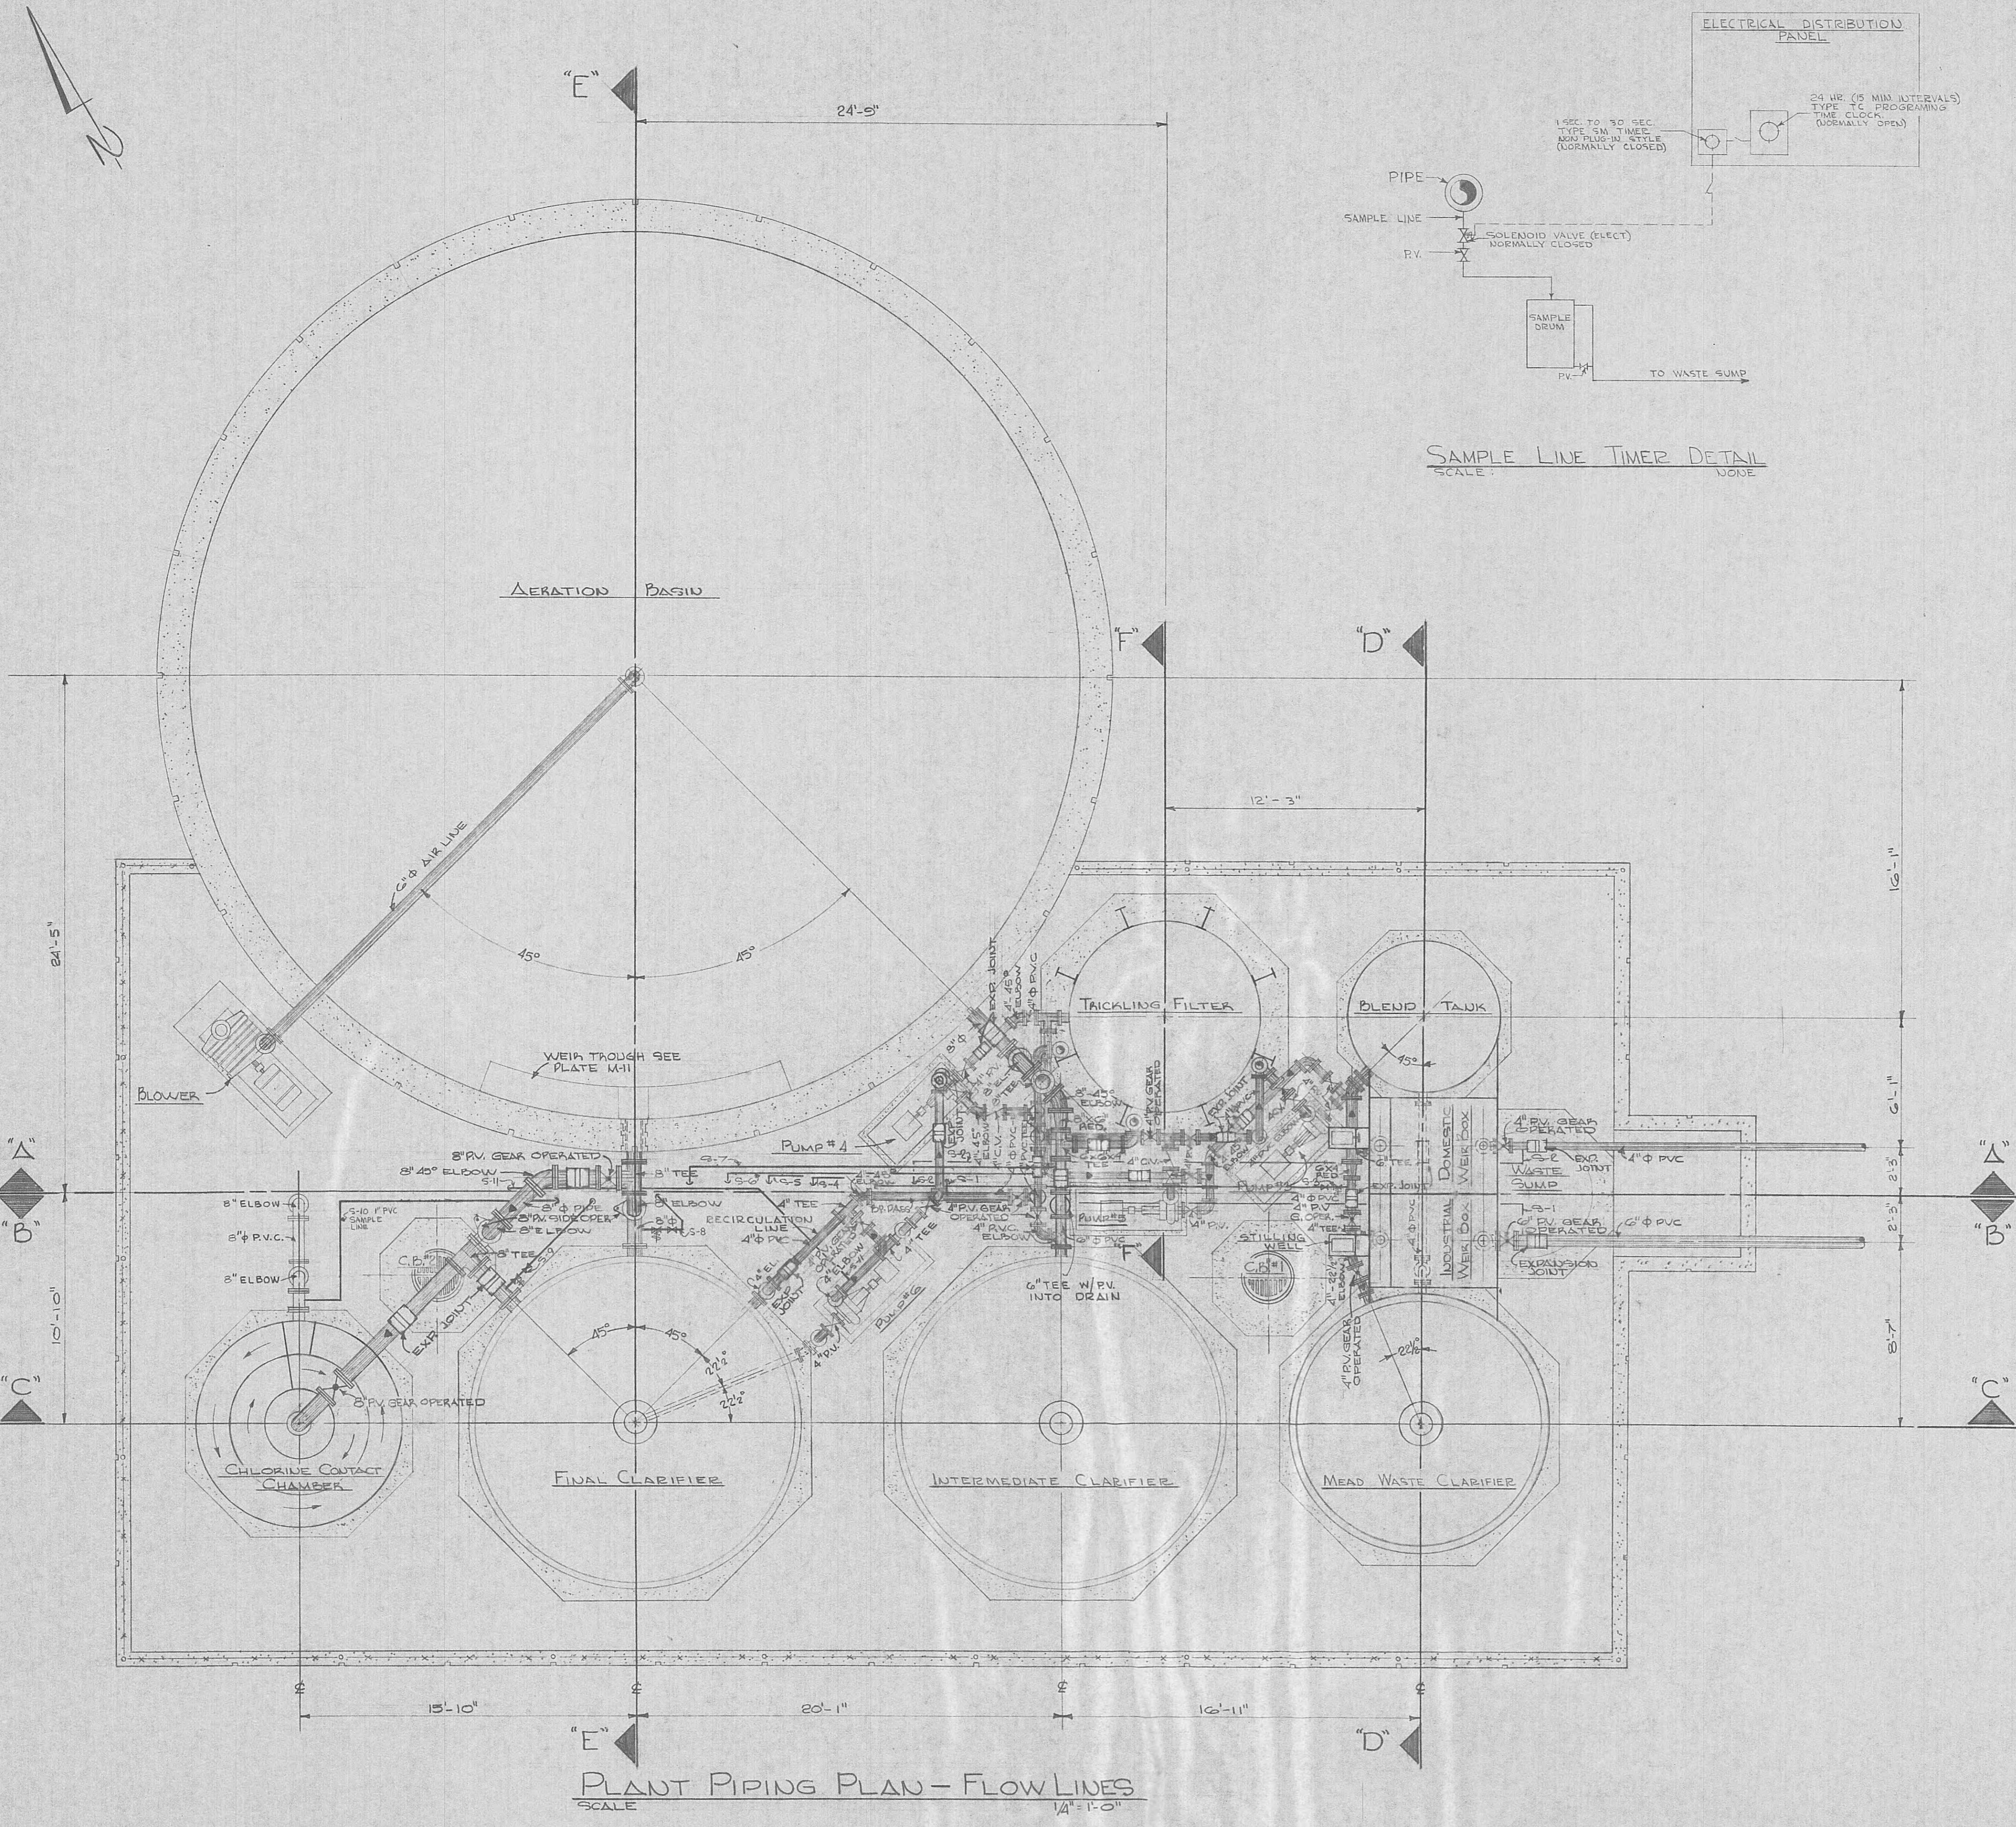

SAMPLE LINE TIMER DETAIL
SCALE: NONE

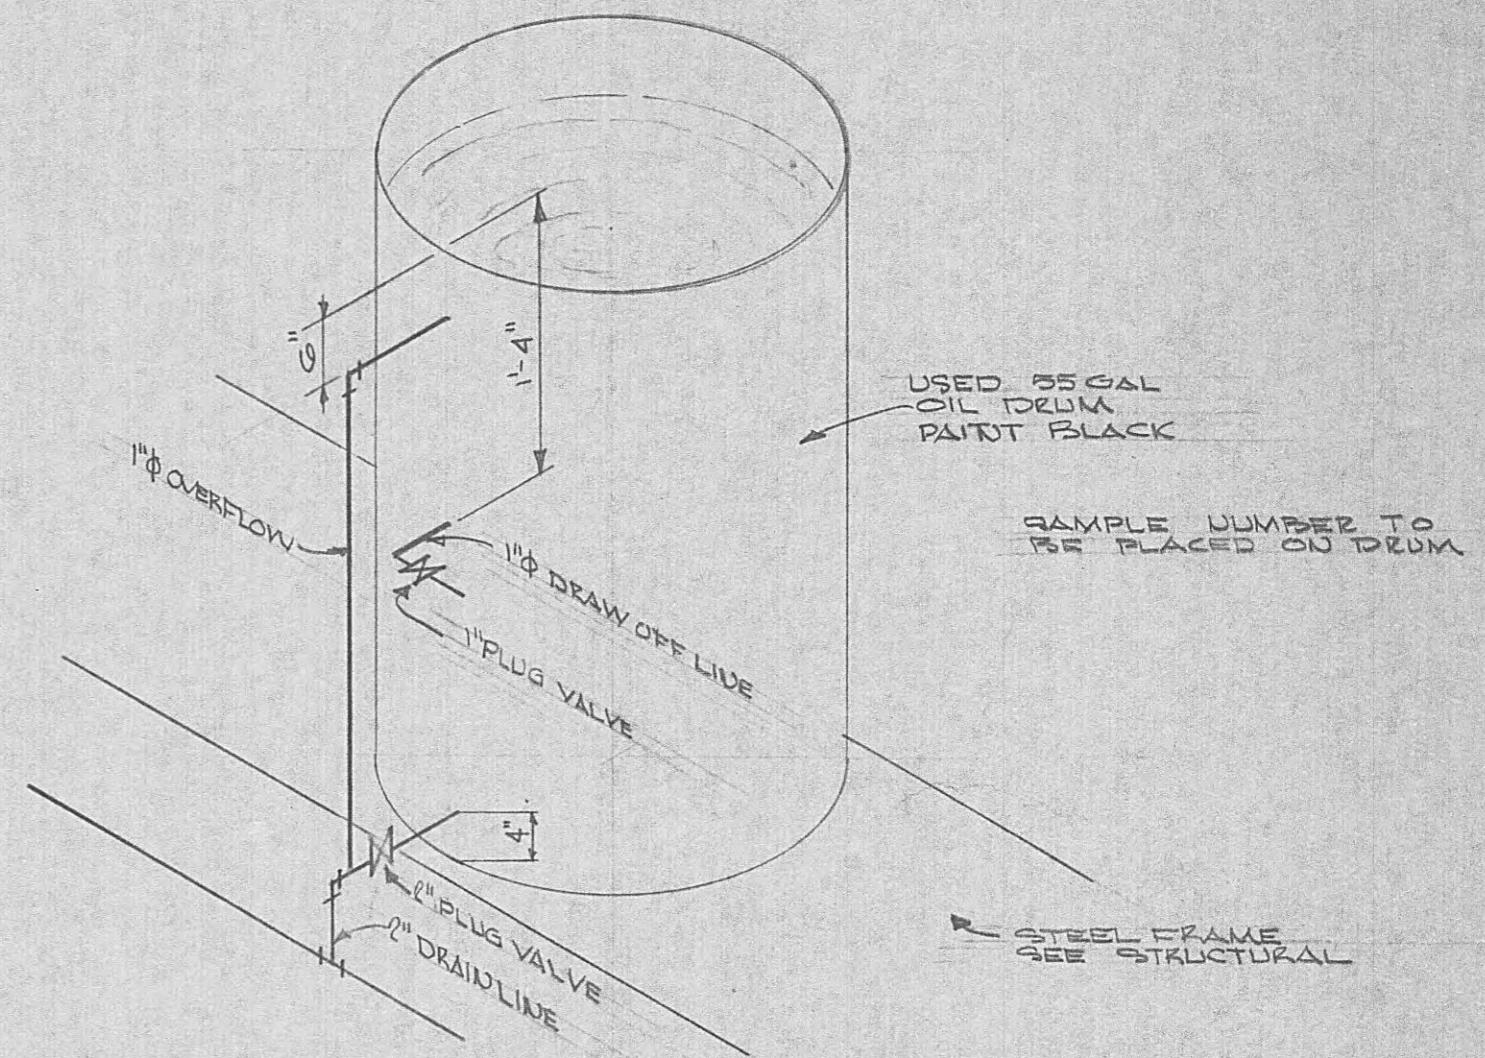

SAMPLE DRUM DETAIL
SCALE: NONE

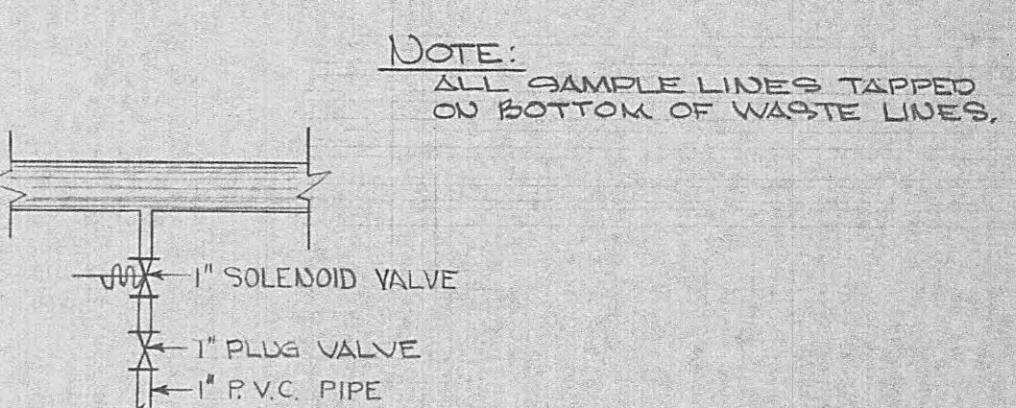

DETAIL SAMPLE LINE CONVENTION
SCALE: NONE

NOTE:
ALL EXPANSION JOINTS SHALL BE INSTALLED TO ALLOW FOR BOTH EXPANSION AND CONTRACTION IN A TEMP RANGE OF 0°F TO 150°F.

PILOT WASTEWATER TREATMENT PLANT
FOR HARRIMAN UTILITY BOARD
TENNESSEE

ROBERT D. WILROY
No. 30-7
REGISTERED ENGINEER


BLACK, CROW AND EIDSNESS, INC.
ATLANTA, GEORGIA
GAINESVILLE, FLORIDA

DRAWN BY: EDWARDS DATE: JUNE 60
CHECKED BY: TDR FILE NO.: 484-69-1


SCALE: 1/4" SHOWS

| | | |
|-----|--------------|--------------------------|
| NO. | DESCRIPTION | DATE |
| M-4 | PLATE NO. 14 | PLATE SHEET NO. 15 OF 26 |

PLANT PIPING PLAN
FLOW LINES

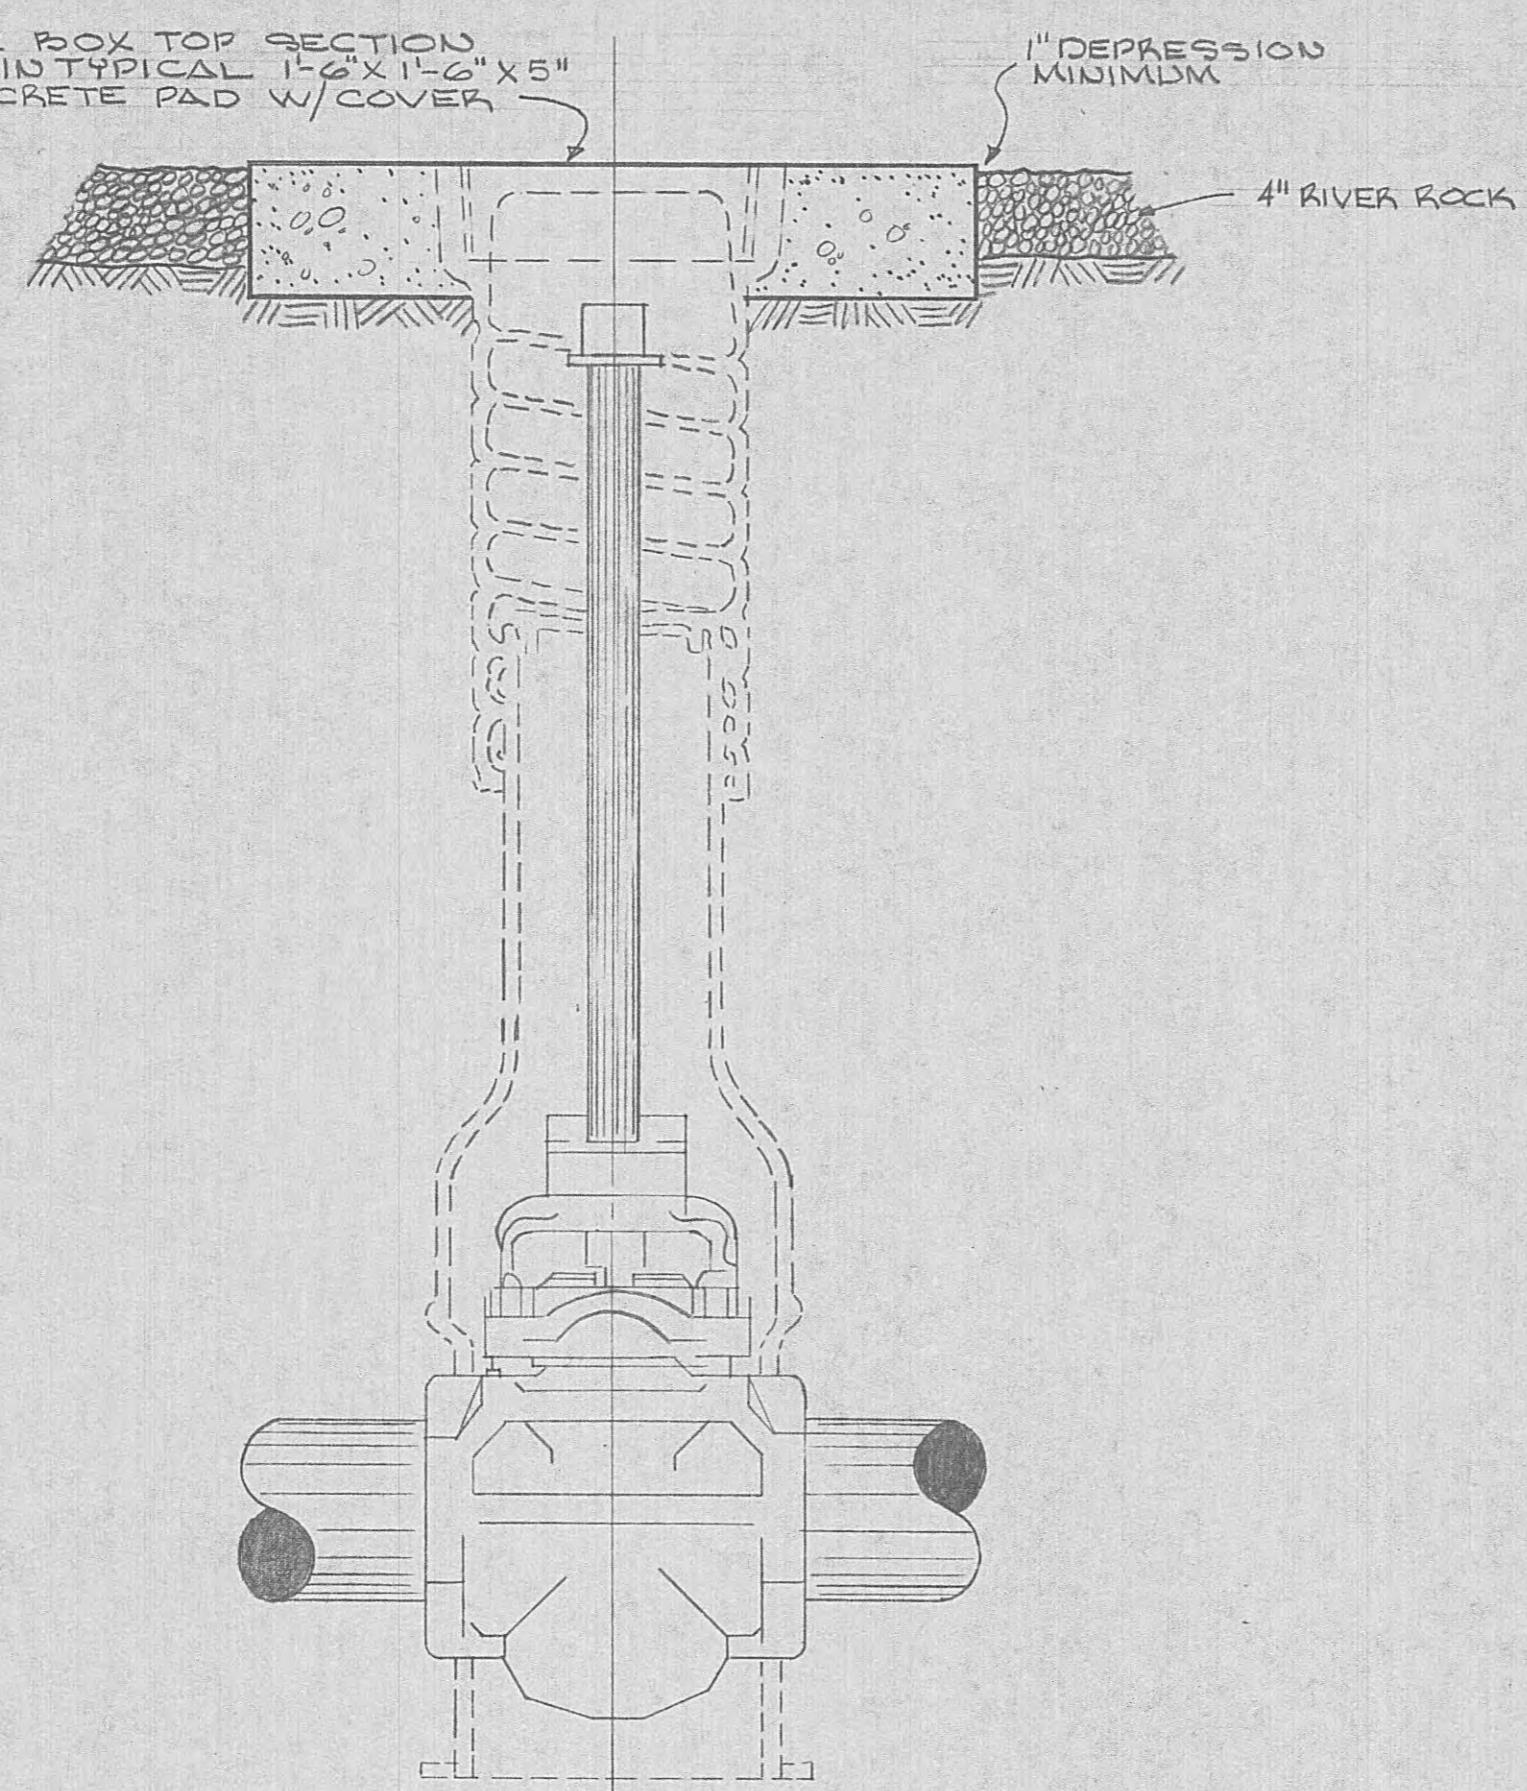

TYPICAL UNDERGROUND PLUG VALVE

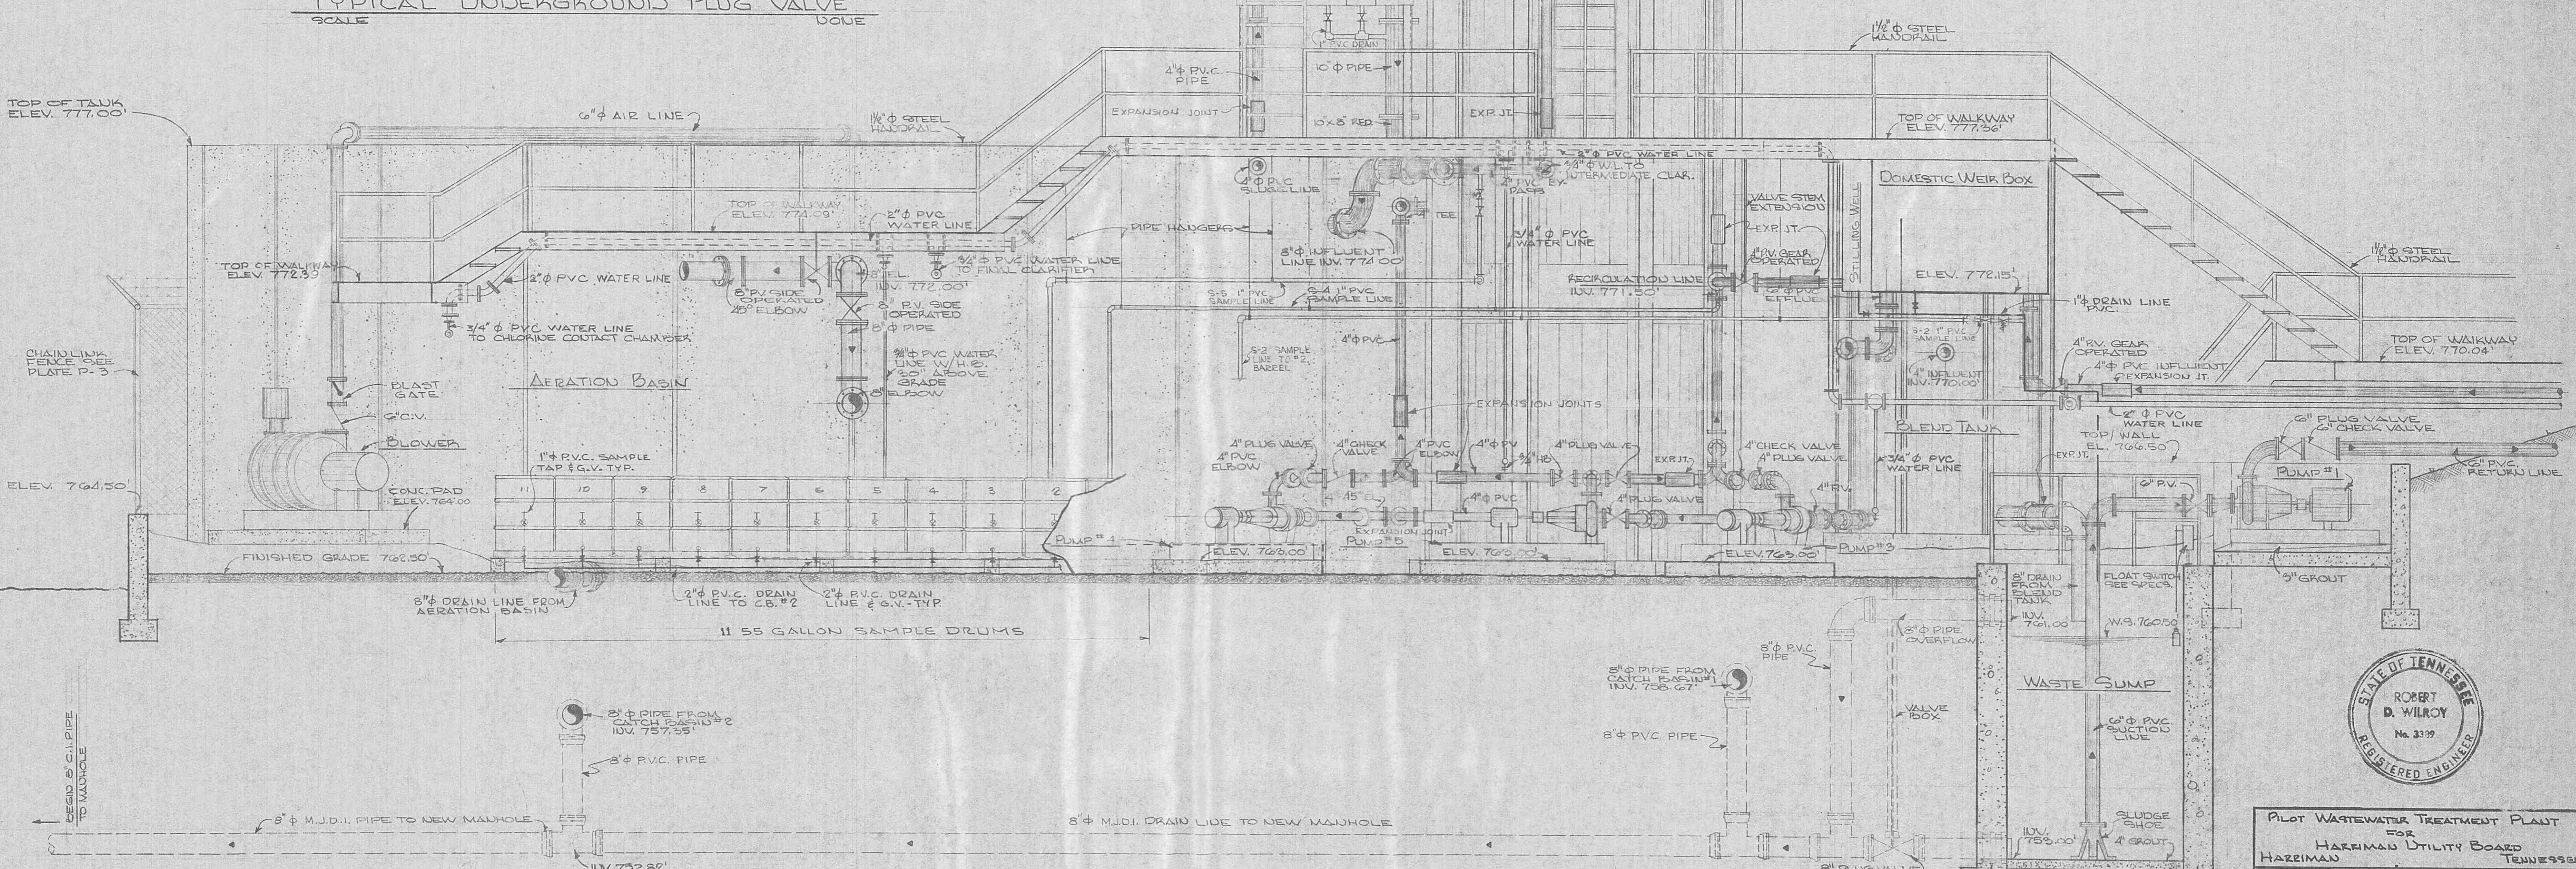

Pilot Wastewater Treatment Plant
FOR
HARRIMAN UTILITY BOARD
HARRIMAN TENNESSEE

BLACK, CROW AND EIDSNESS, INC.
ATLANTA ENGINEERS GEORGIA
GAINESVILLE FLORIDA

DRAWN BY: EDWARD S. DATE: JUNE 19
CHECKED BY: T.D.R. FILE NO.: 484-69-1
SCALE: AS SHOWN


PLATE NO. SHEE NO.

CONSTITUTIONAL SECTION M-3 15
OF 13 OF 26

Digitized by srujanika@gmail.com

SECTION "A-A"


NOTE:
 1. ALL THROTTLING VALVES
 ARE GEAR OPERATED.
 2. ALL EXPANSION JOINTS
 SHALL BE INSTALLED TO
 ALLOW FOR BOTH EXPANSION
 AND CONTRACTION IN A TEMP.
 RANGE OF 0°F. TO 150°F.


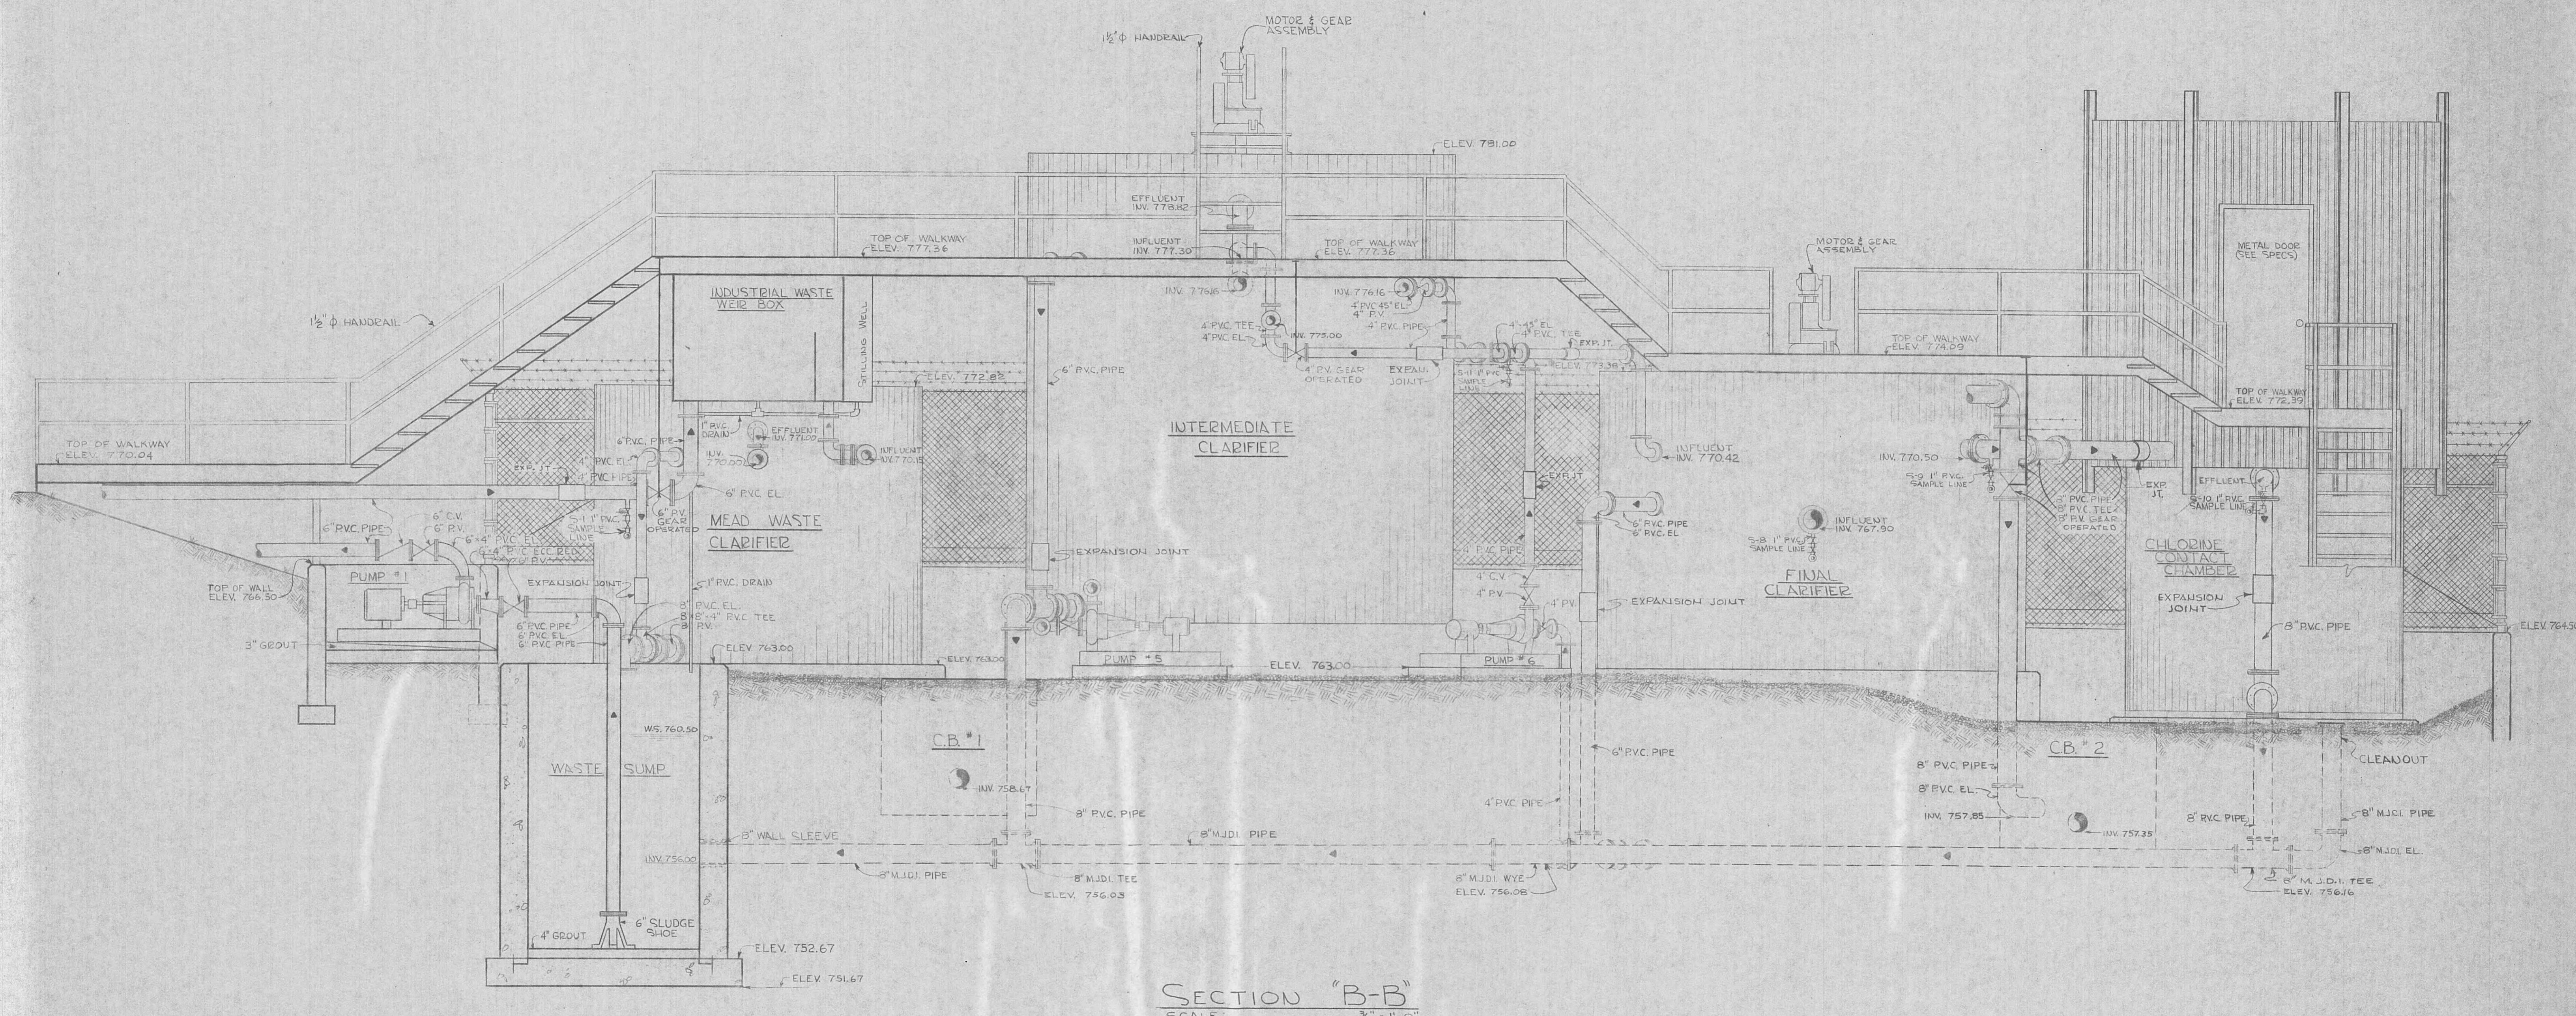


| | | |
|---|-------------|------|
| PILOT WASTEWATER TREATMENT PLANT FOR HARRIMAN UTILITY BOARD HARRIMAN TENNESSEE | | |
| BLACK, CROW AND EIDNESS, INC. ATLANTA GAINESVILLE GEORGIA FLORIDA | | |
| DRAWN BY: GROVE CHECKED BY: TDR FILE NO.: 484-69-1 | | |
| SCALE: AS SHOWN | | |
| NO. | DESCRIPTION | DATE |
| REVISIONS | | |

LONGITUDINAL SECTION M-6 OF 15

PLATE NO. M-6 SHEET NO. 16 OF 26

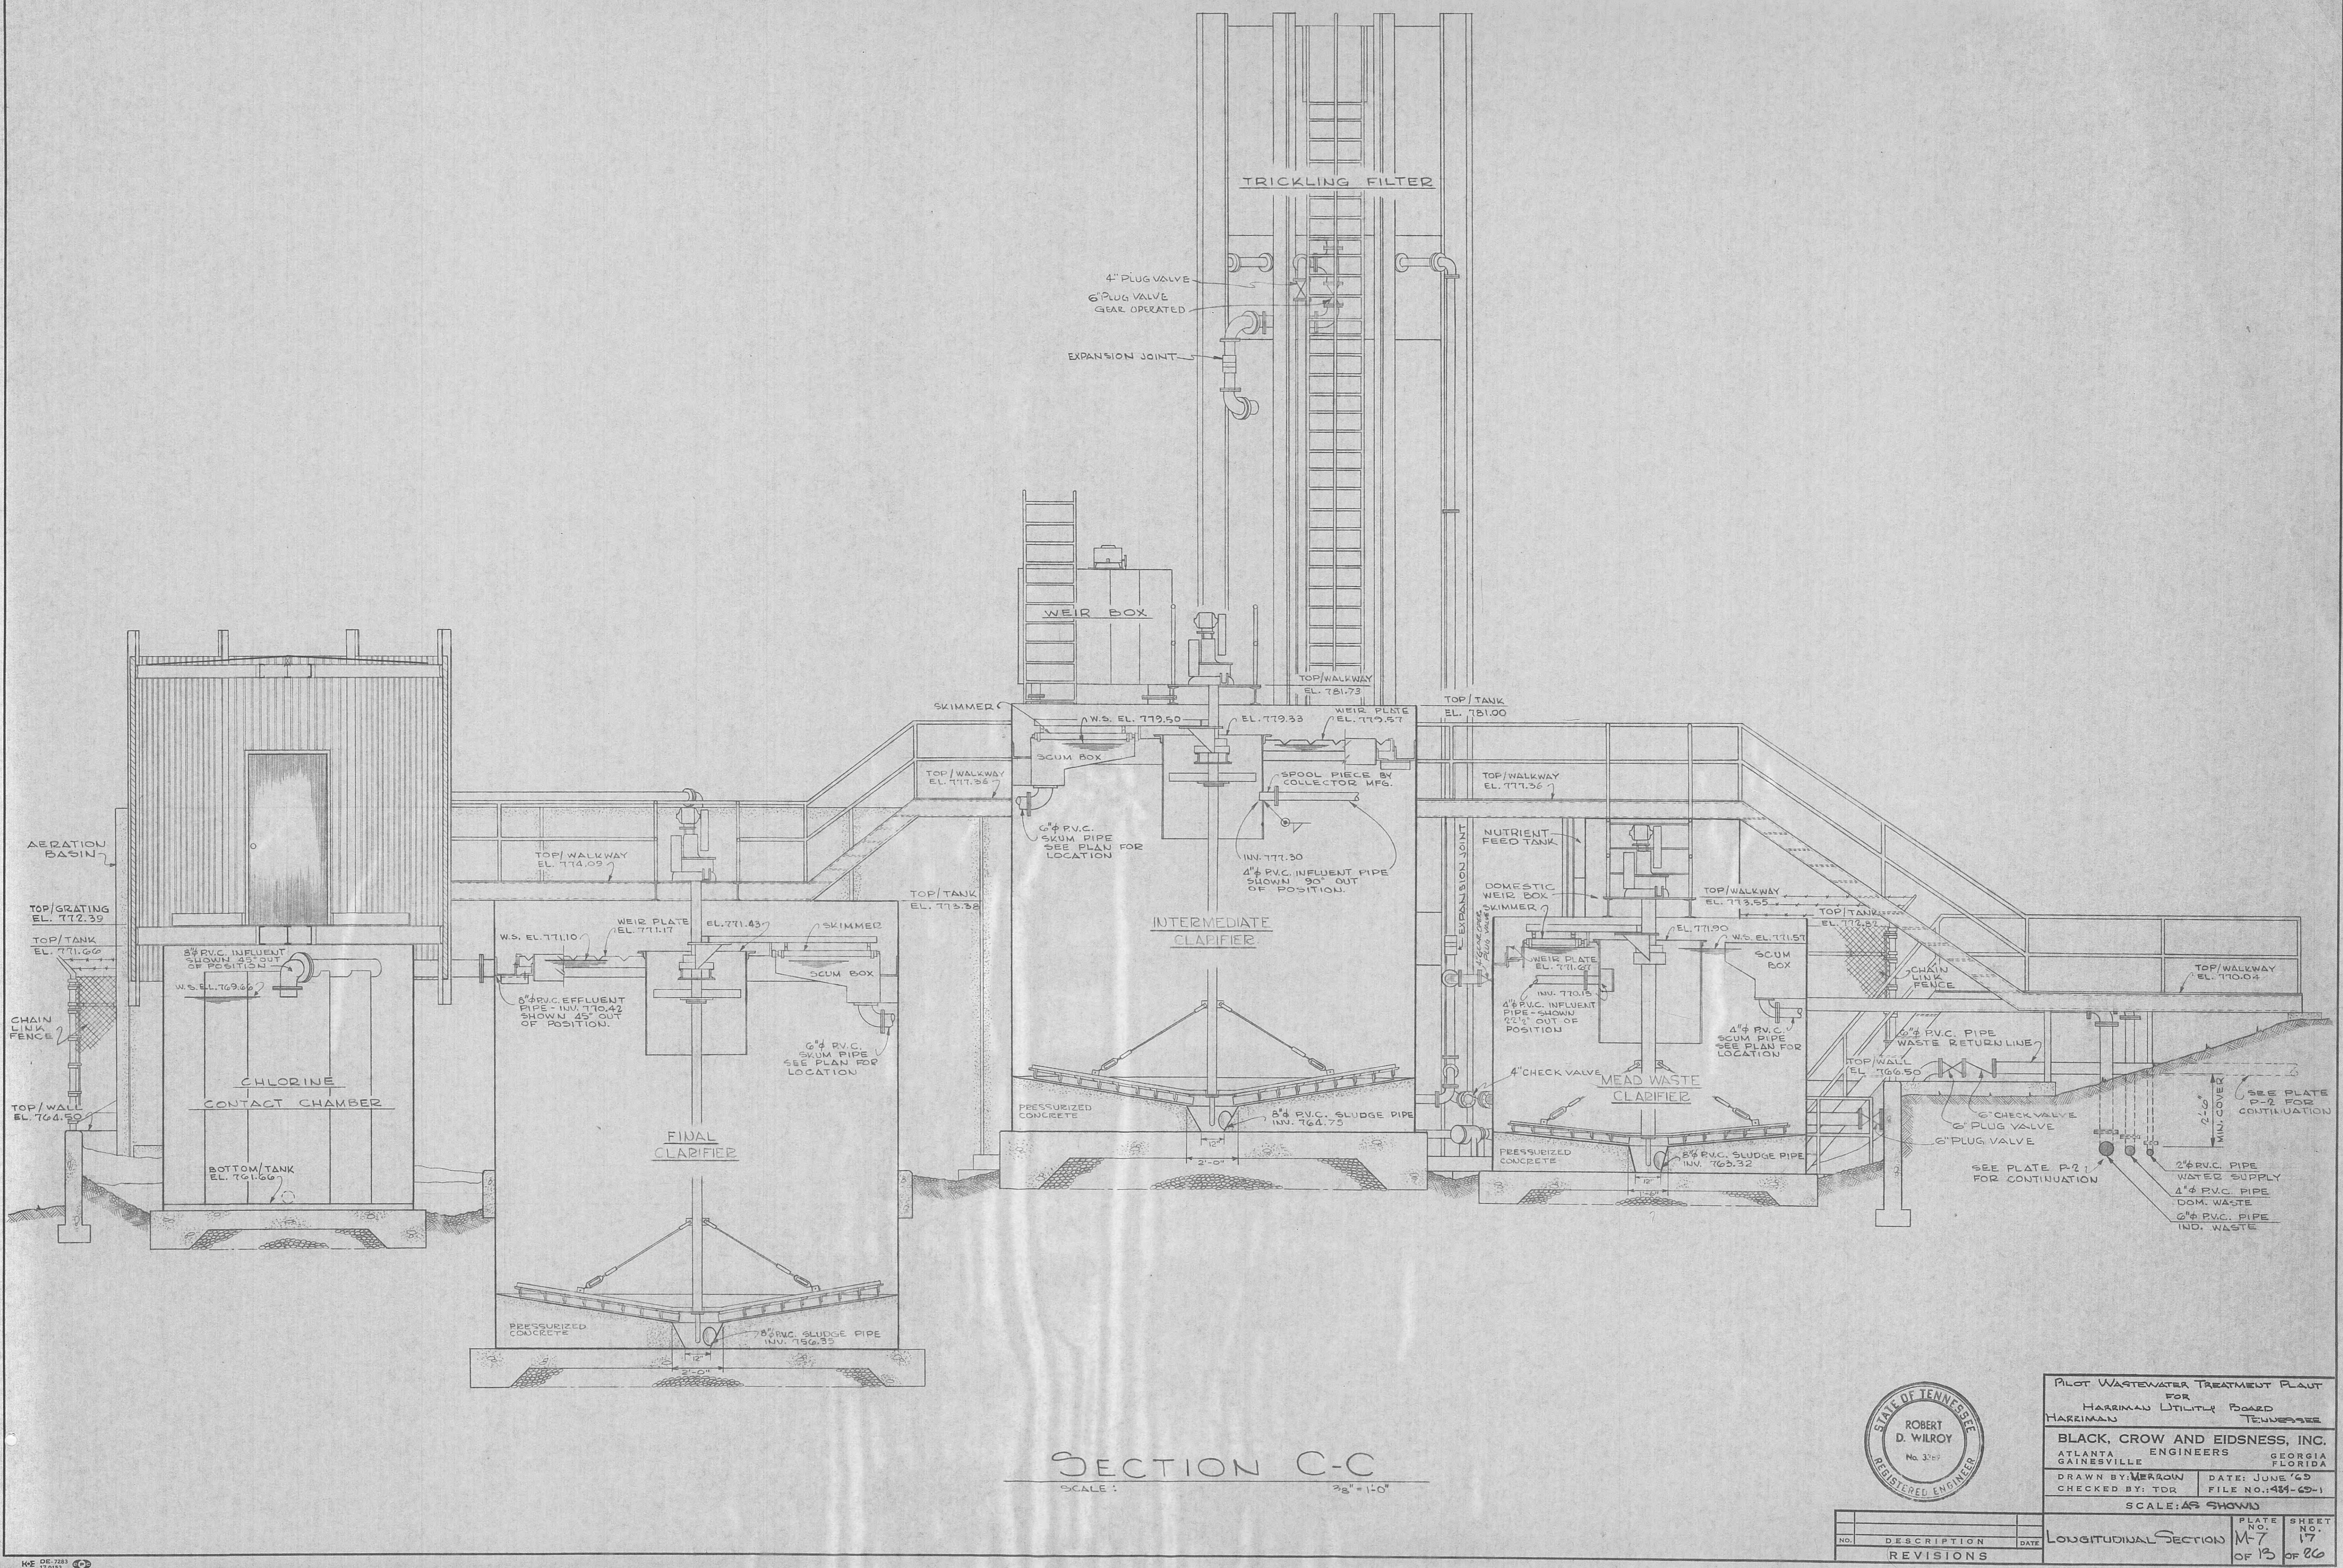

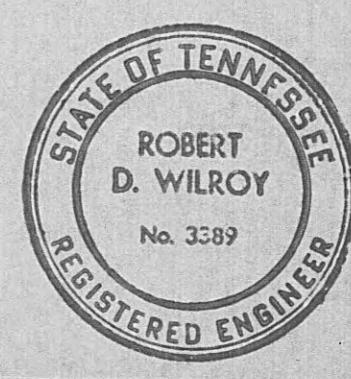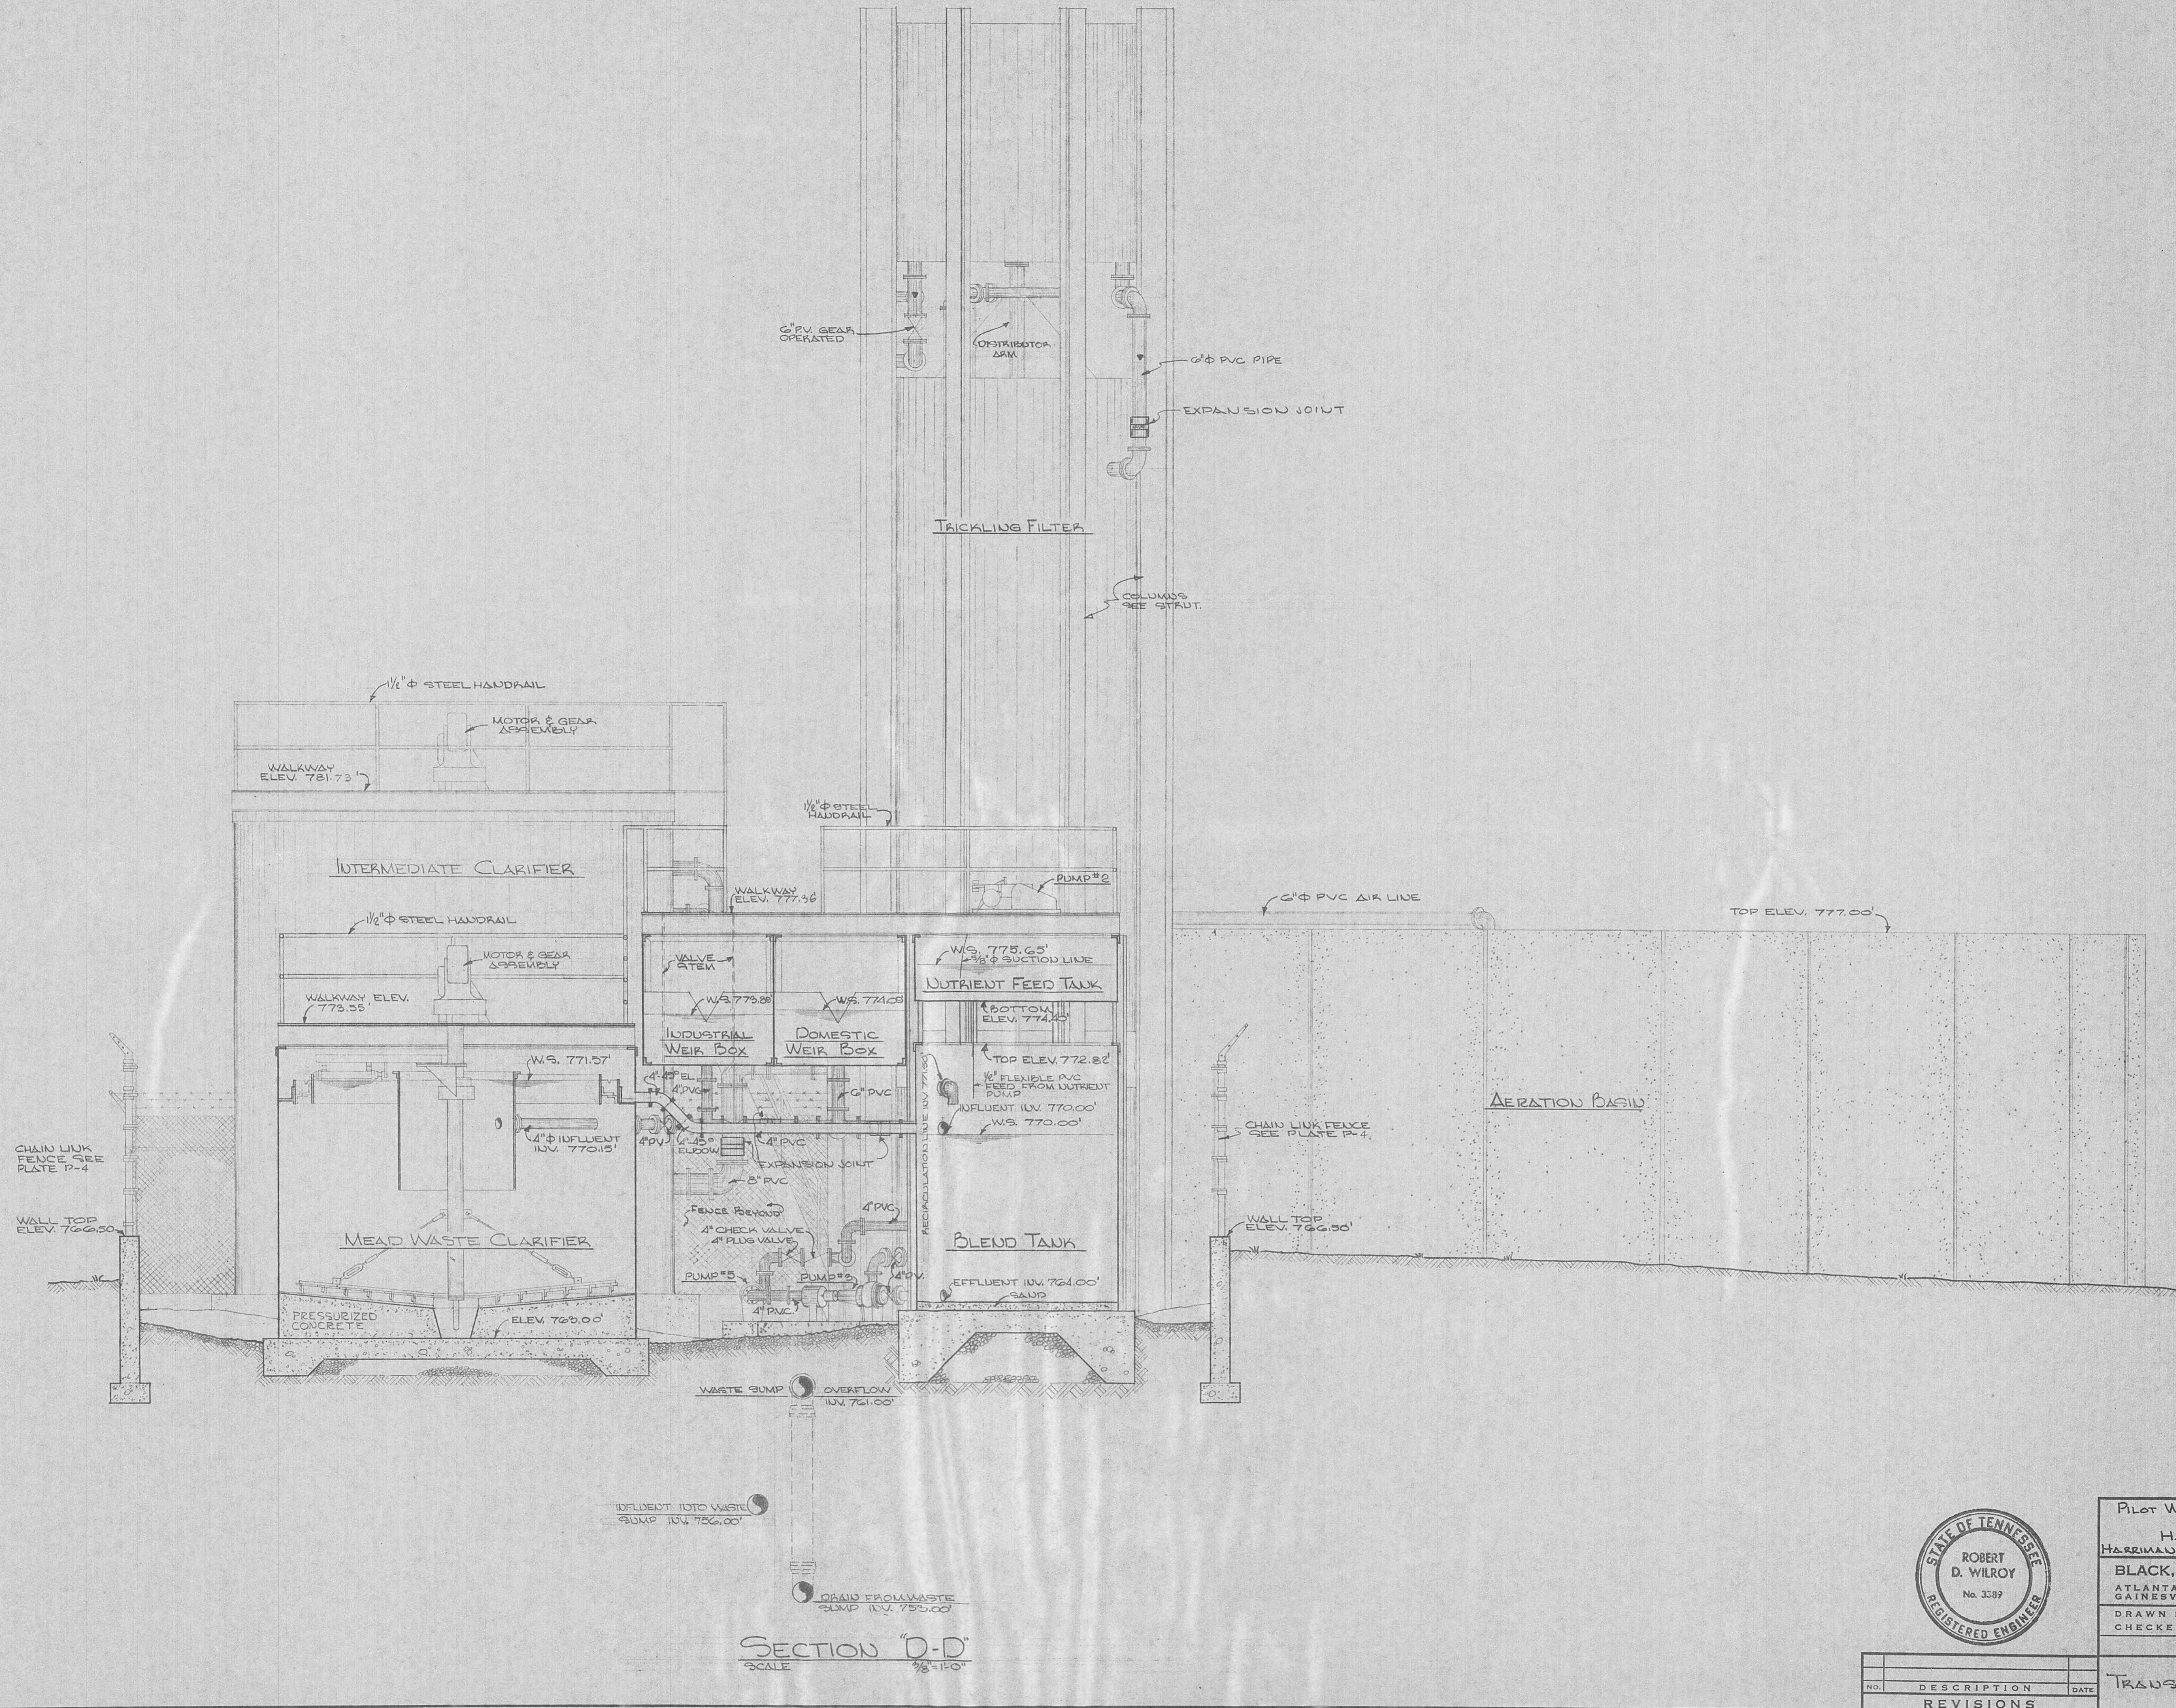


Pilot Wastewater Treatment Plant
FOR
HARRIMAN UTILITY BOARD
HARRIMAN TENNESSEE

BLACK, CROW AND EIDSNESS, INC.
ATLANTA ENGINEERS GEORGIA
GAINESVILLE FLORIDA

DRAWN BY: EDWARDS DATE: JUNE '69
CHECKED BY: TDR FILE NO.: 484-69-1


SCALE: AS SHOWN

| | | |
|--------------------|---------------------------|--------------------------|
| TRANSVERSE SECTION | PLATE NO. M-8 OF 13 | SHEET NO. 18 OF 26 |
|--------------------|---------------------------|--------------------------|

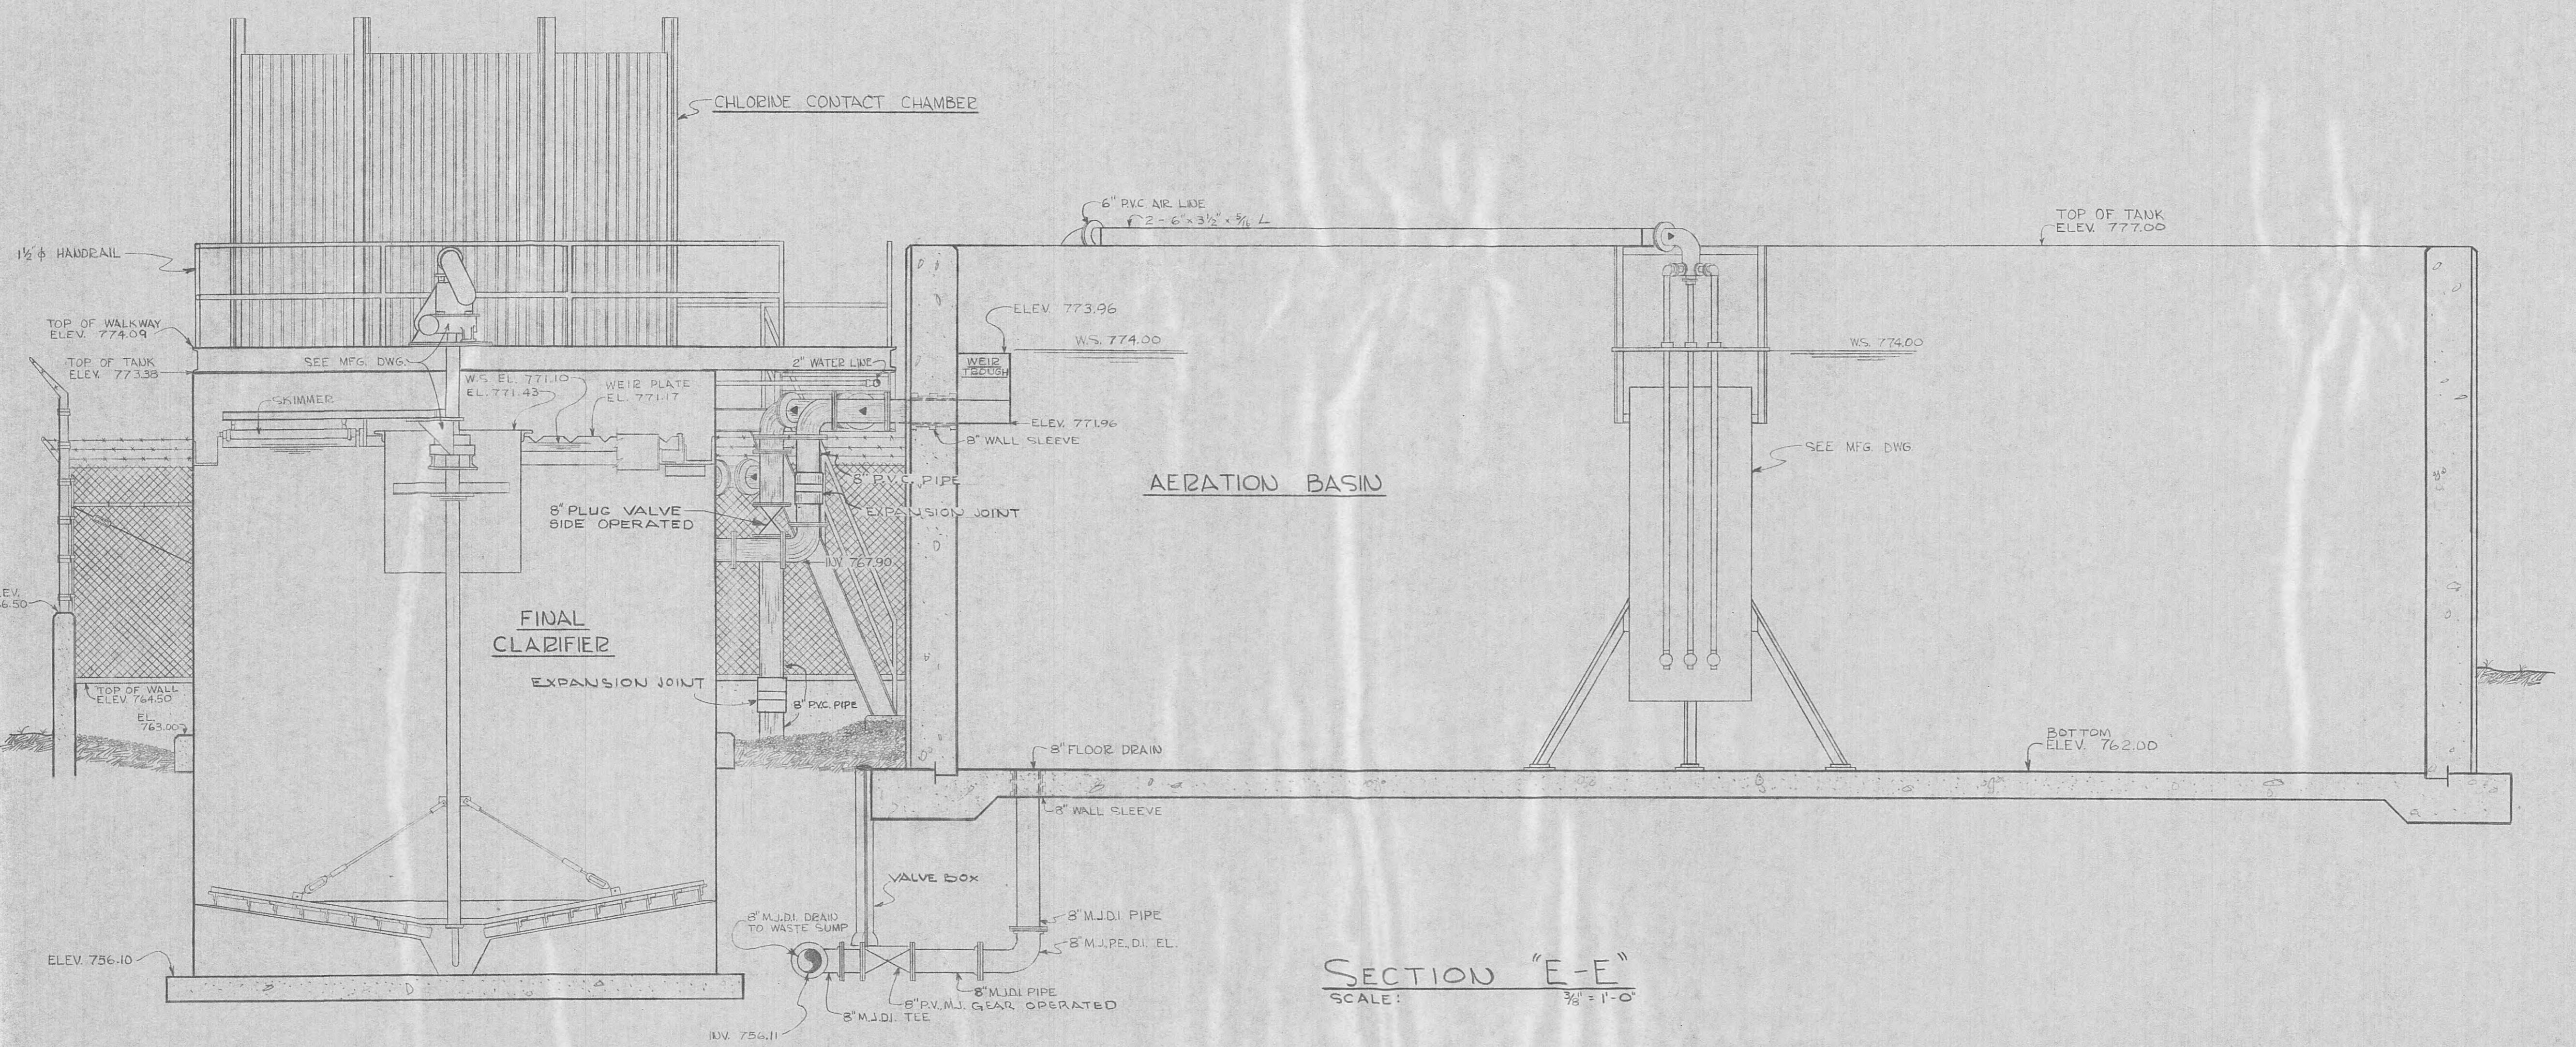

SECTION "E-E"


SECTION L L
SCALE: $\frac{3}{8}'' = 1'-0''$

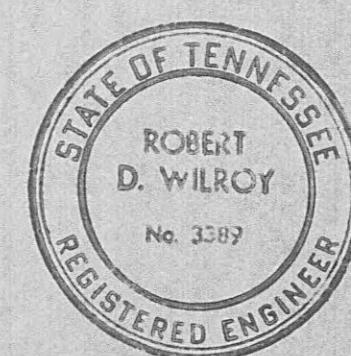



PILOT WASTEWATER TREATMENT PLANT
 FOR
 HARRIMAN UTILITY BOARD
 HARRIMAN TENNESSEE
 BLACK, CROW AND EIDSNESS, INC.
 ATLANTA ENGINEERS GEORGIA
 GAINESVILLE FLORIDA
 DRAWN BY: GROVE DATE: JUNE '69
 CHECKED BY: TDR FILE NO.: 484-69-1
 SCALE: AS SHOWN

| NO. | DESCRIPTION | DATE |
|-----|-------------|------|
| | REVISIONS | T |


TRANSVERSE SECTION NO. M-9 N.O. 19
OF 13 OF 26

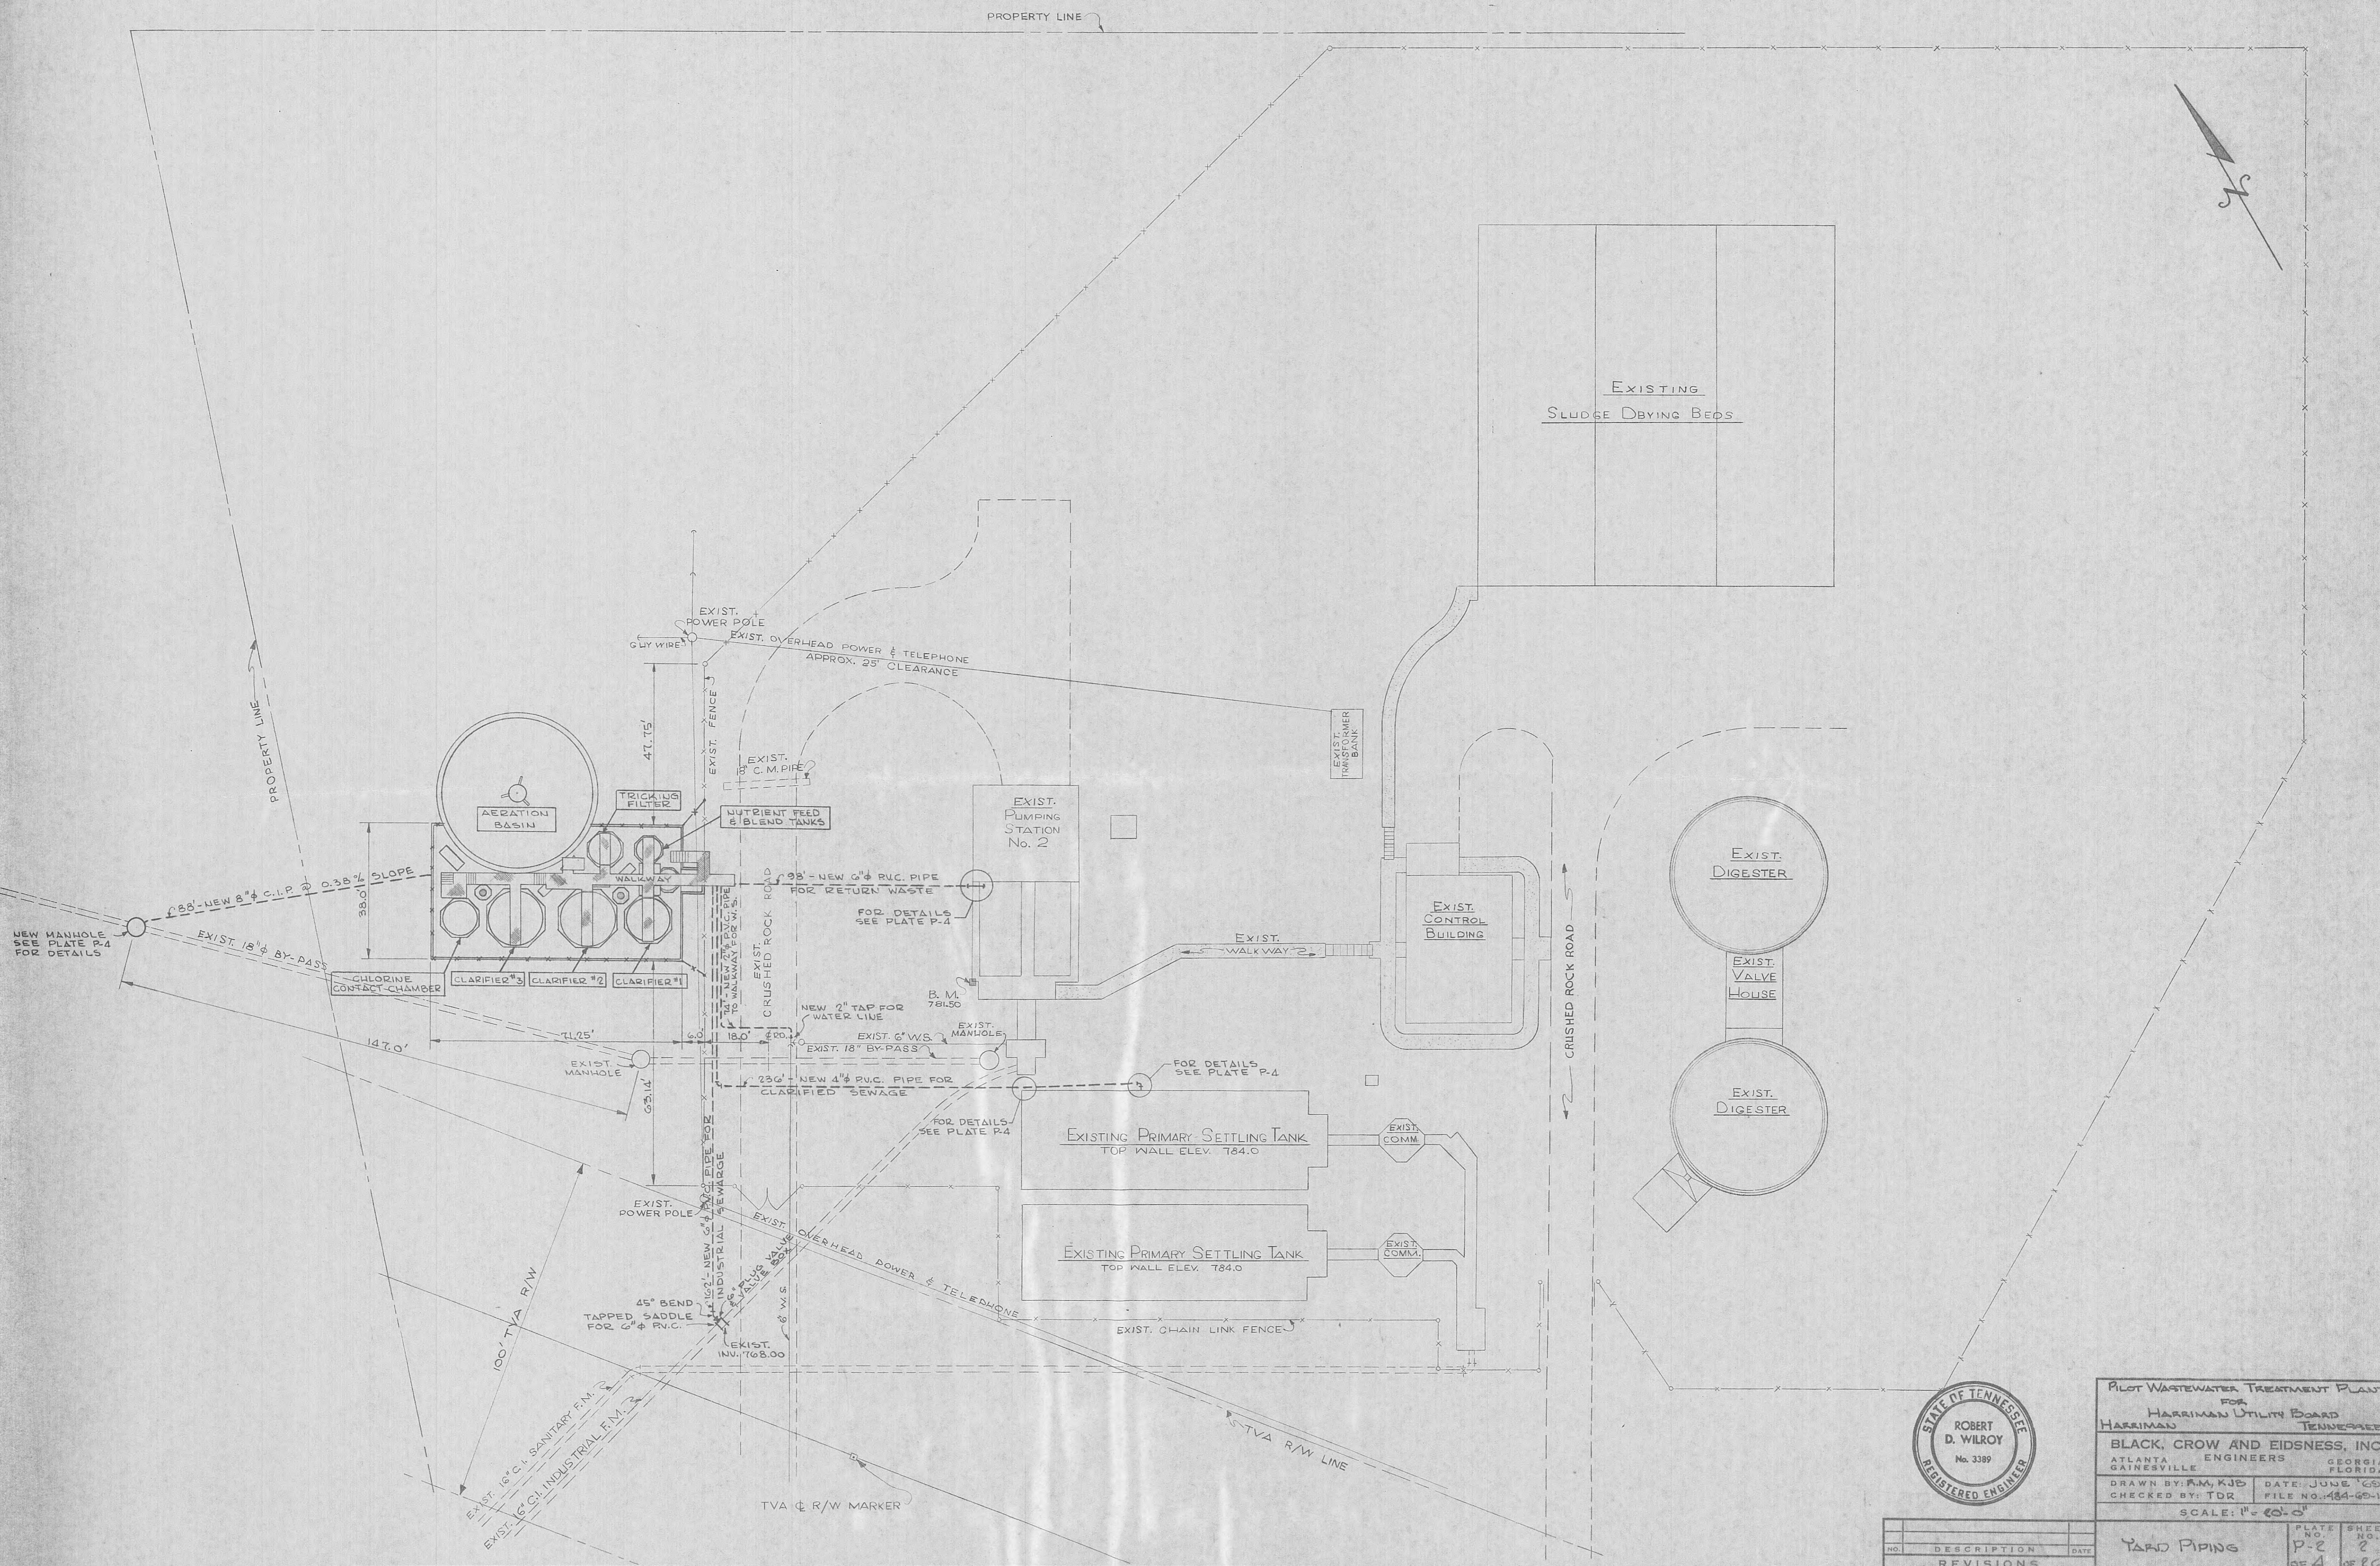

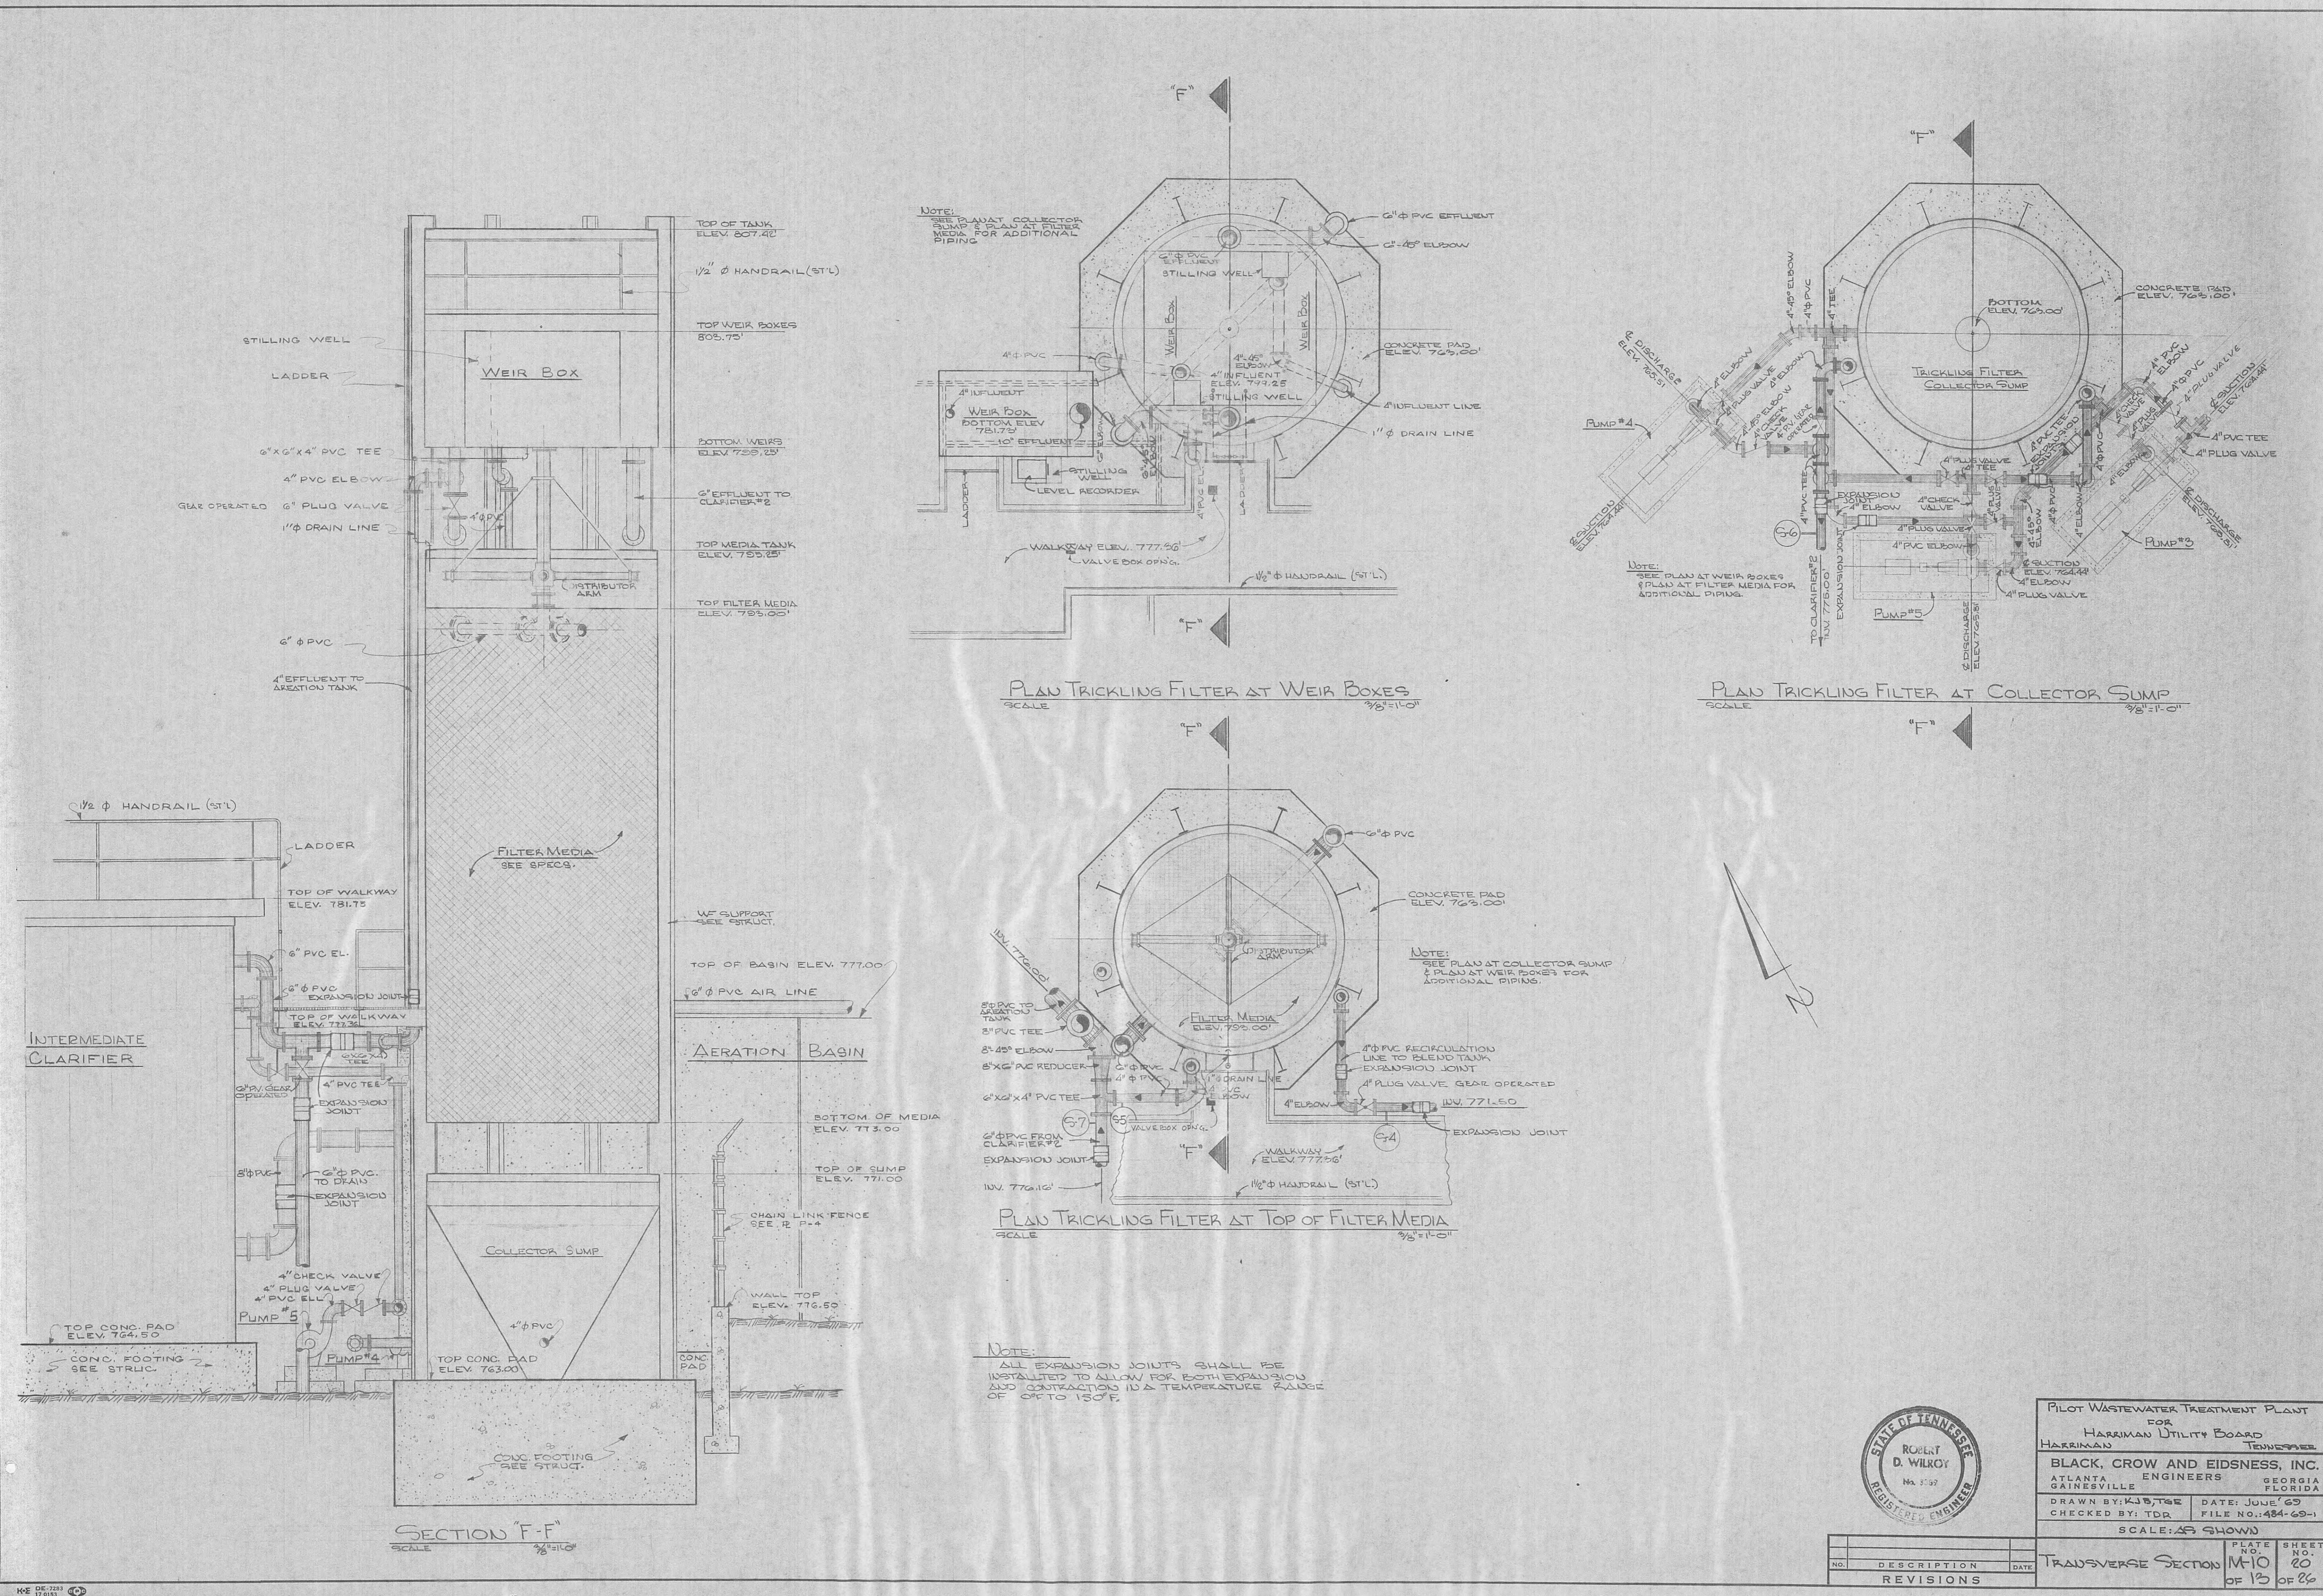


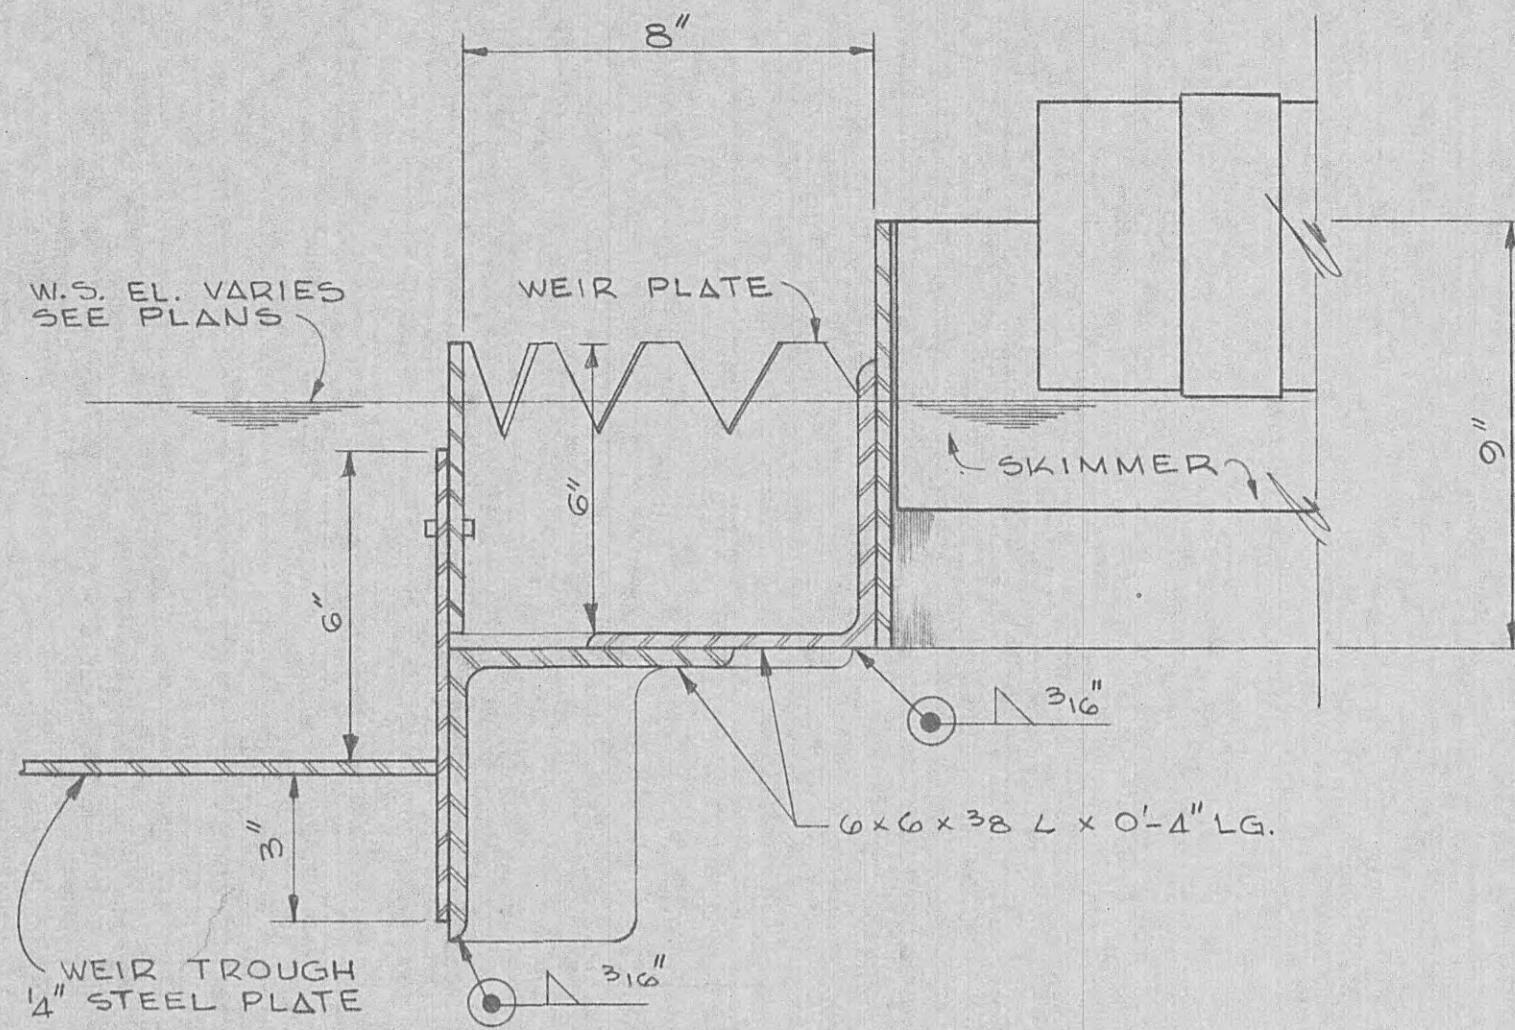


TYPICAL SCUM
BAFFLE BRACKET DETAIL
SCALE: $\frac{1}{2}'' = 1'-0''$

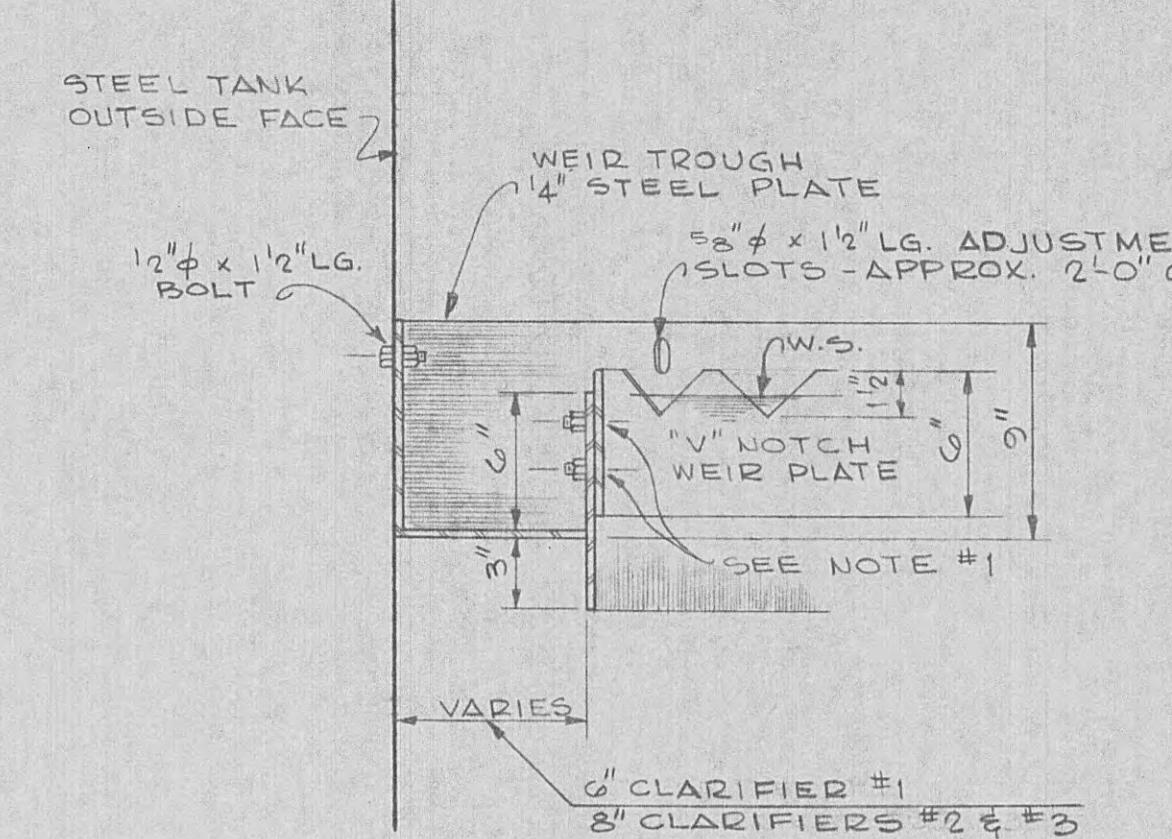

TYPICAL DETAIL OF
WEIR TROUGH
SCALE: $\frac{1}{2}'' = 1'-0''$

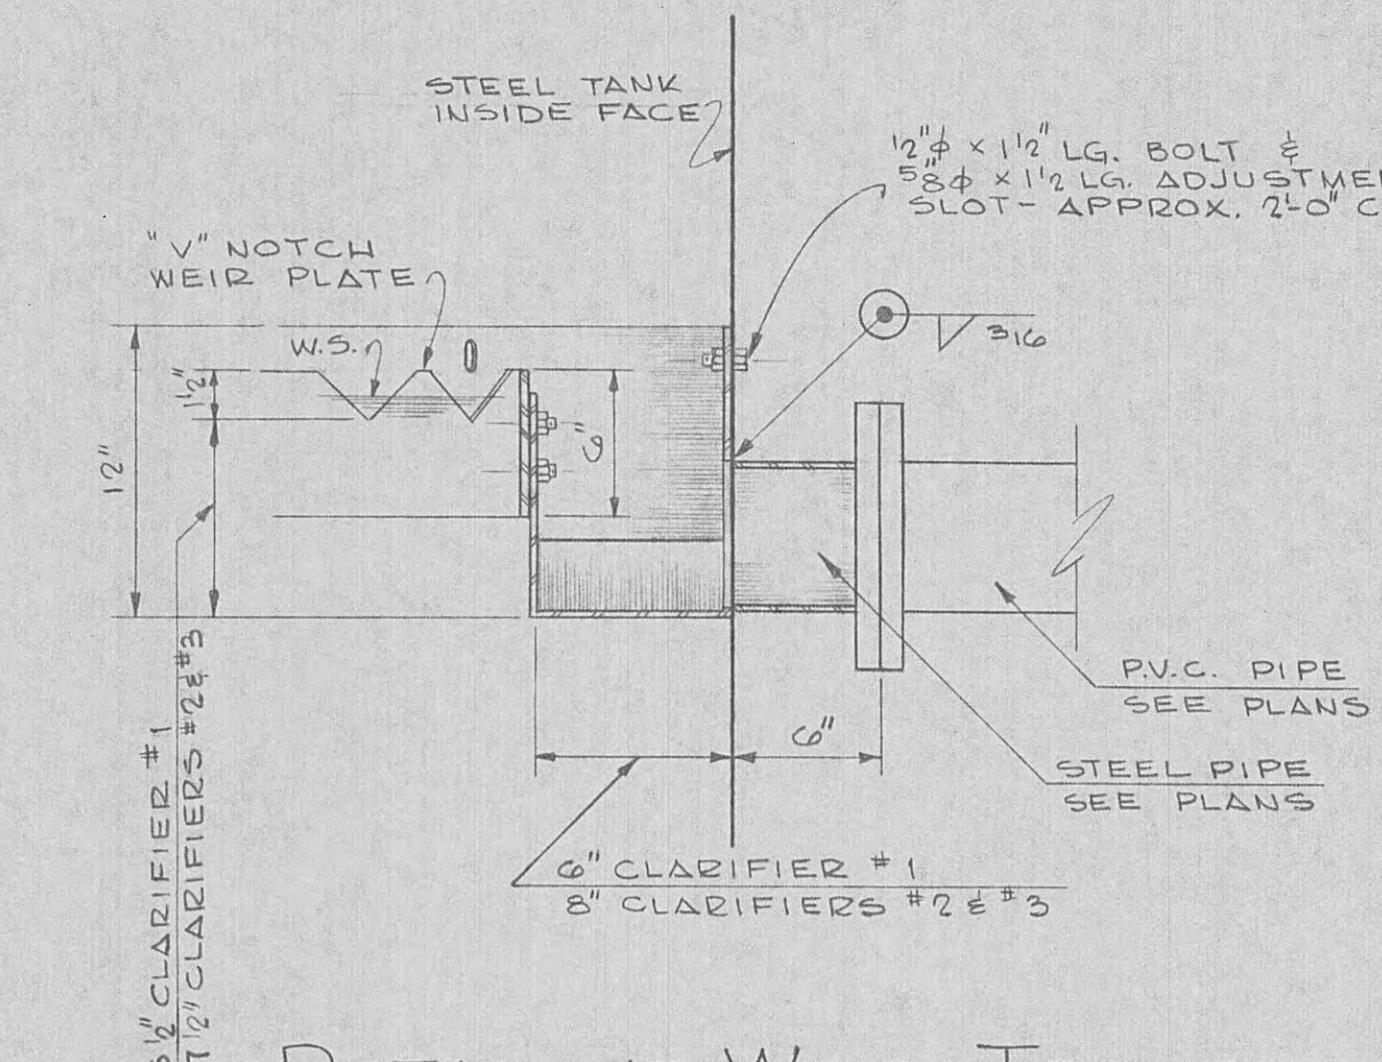


DETAIL AT WEIR TROUGH
EFFLUENT
SCALE: $\frac{1}{2}'' = 1'-0''$

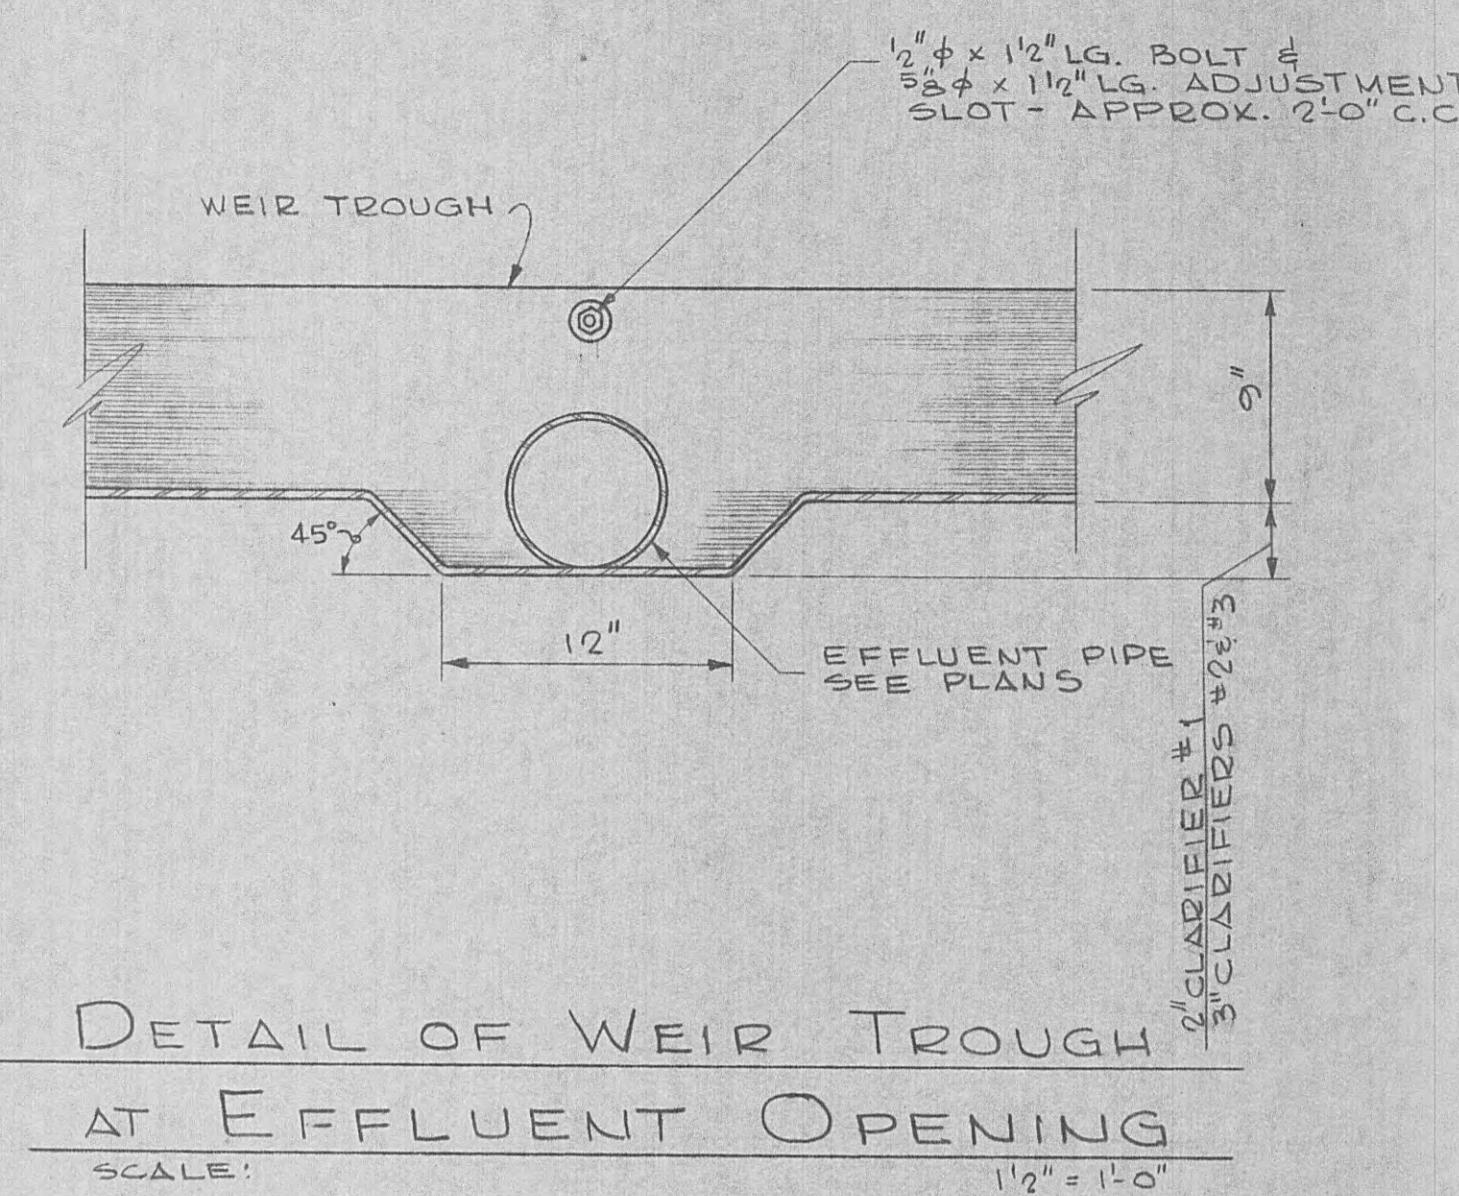


DETAIL OF WEIR TROUGH
AT EFFLUENT OPENING
SCALE: $\frac{1}{2}'' = 1'-0''$

WEIR DETAILS FOR CLARIFIERS #1, #2 & #3


AS NOTED

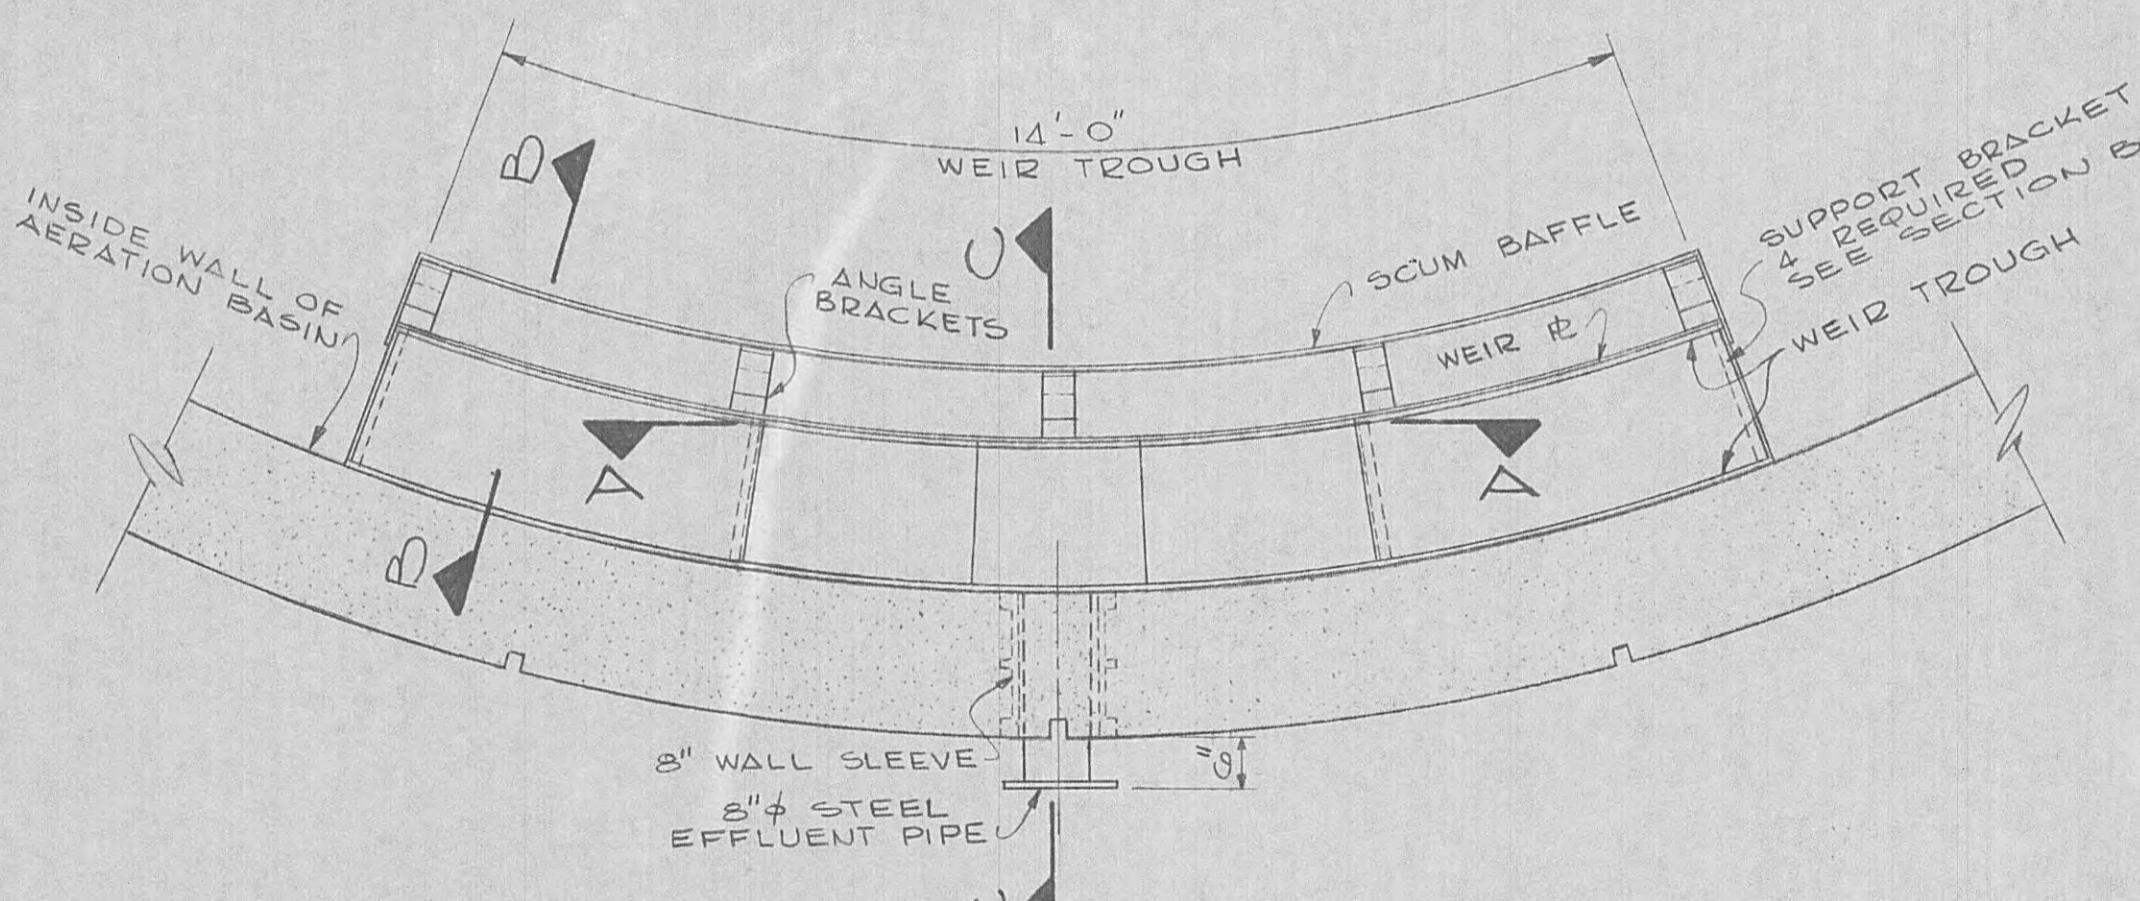

PLAN
SCALE: $\frac{1}{2}'' = 1'-0''$

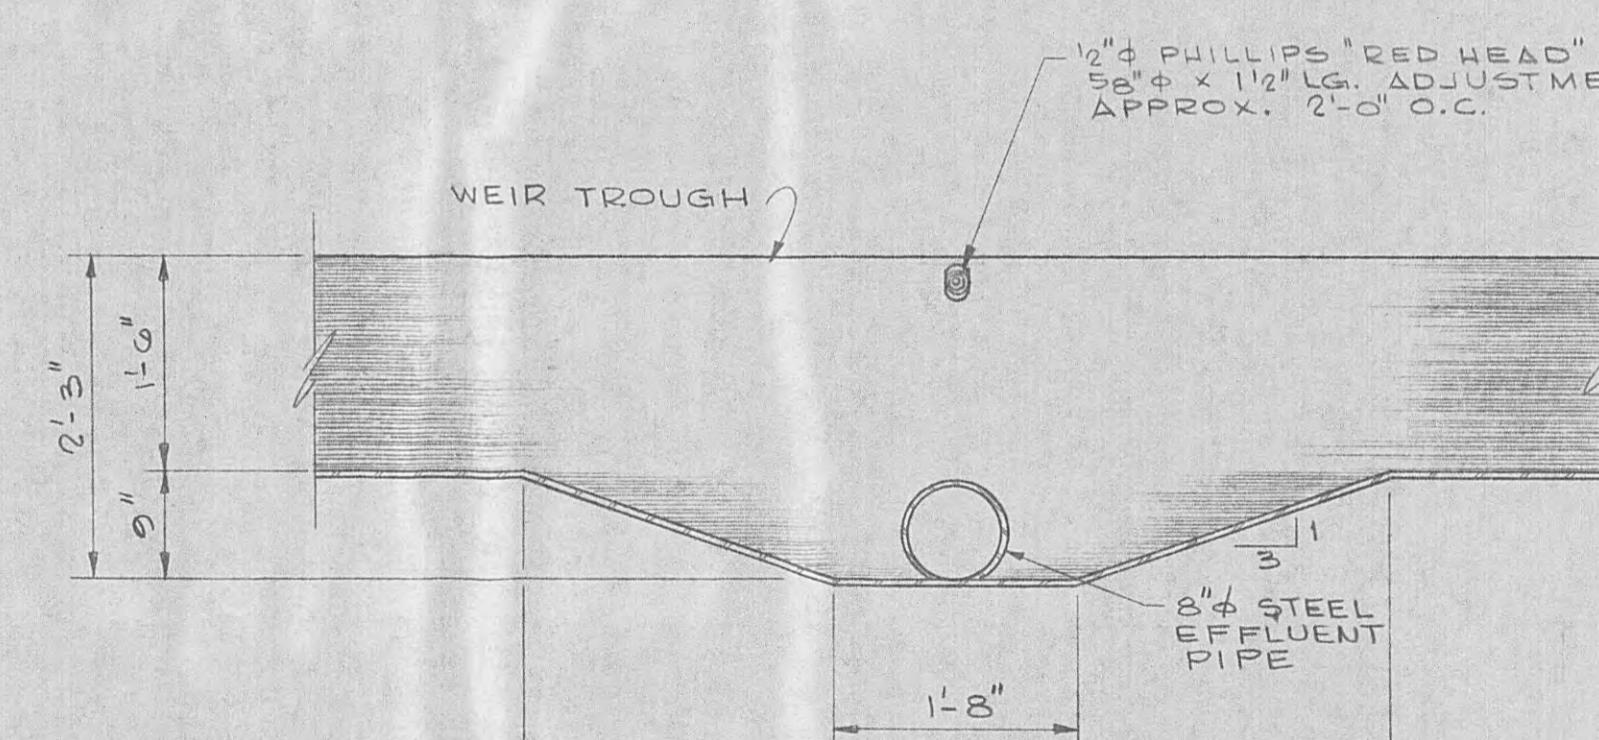


SECTION A-A
SCALE: $\frac{1}{2}'' = 1'-0''$

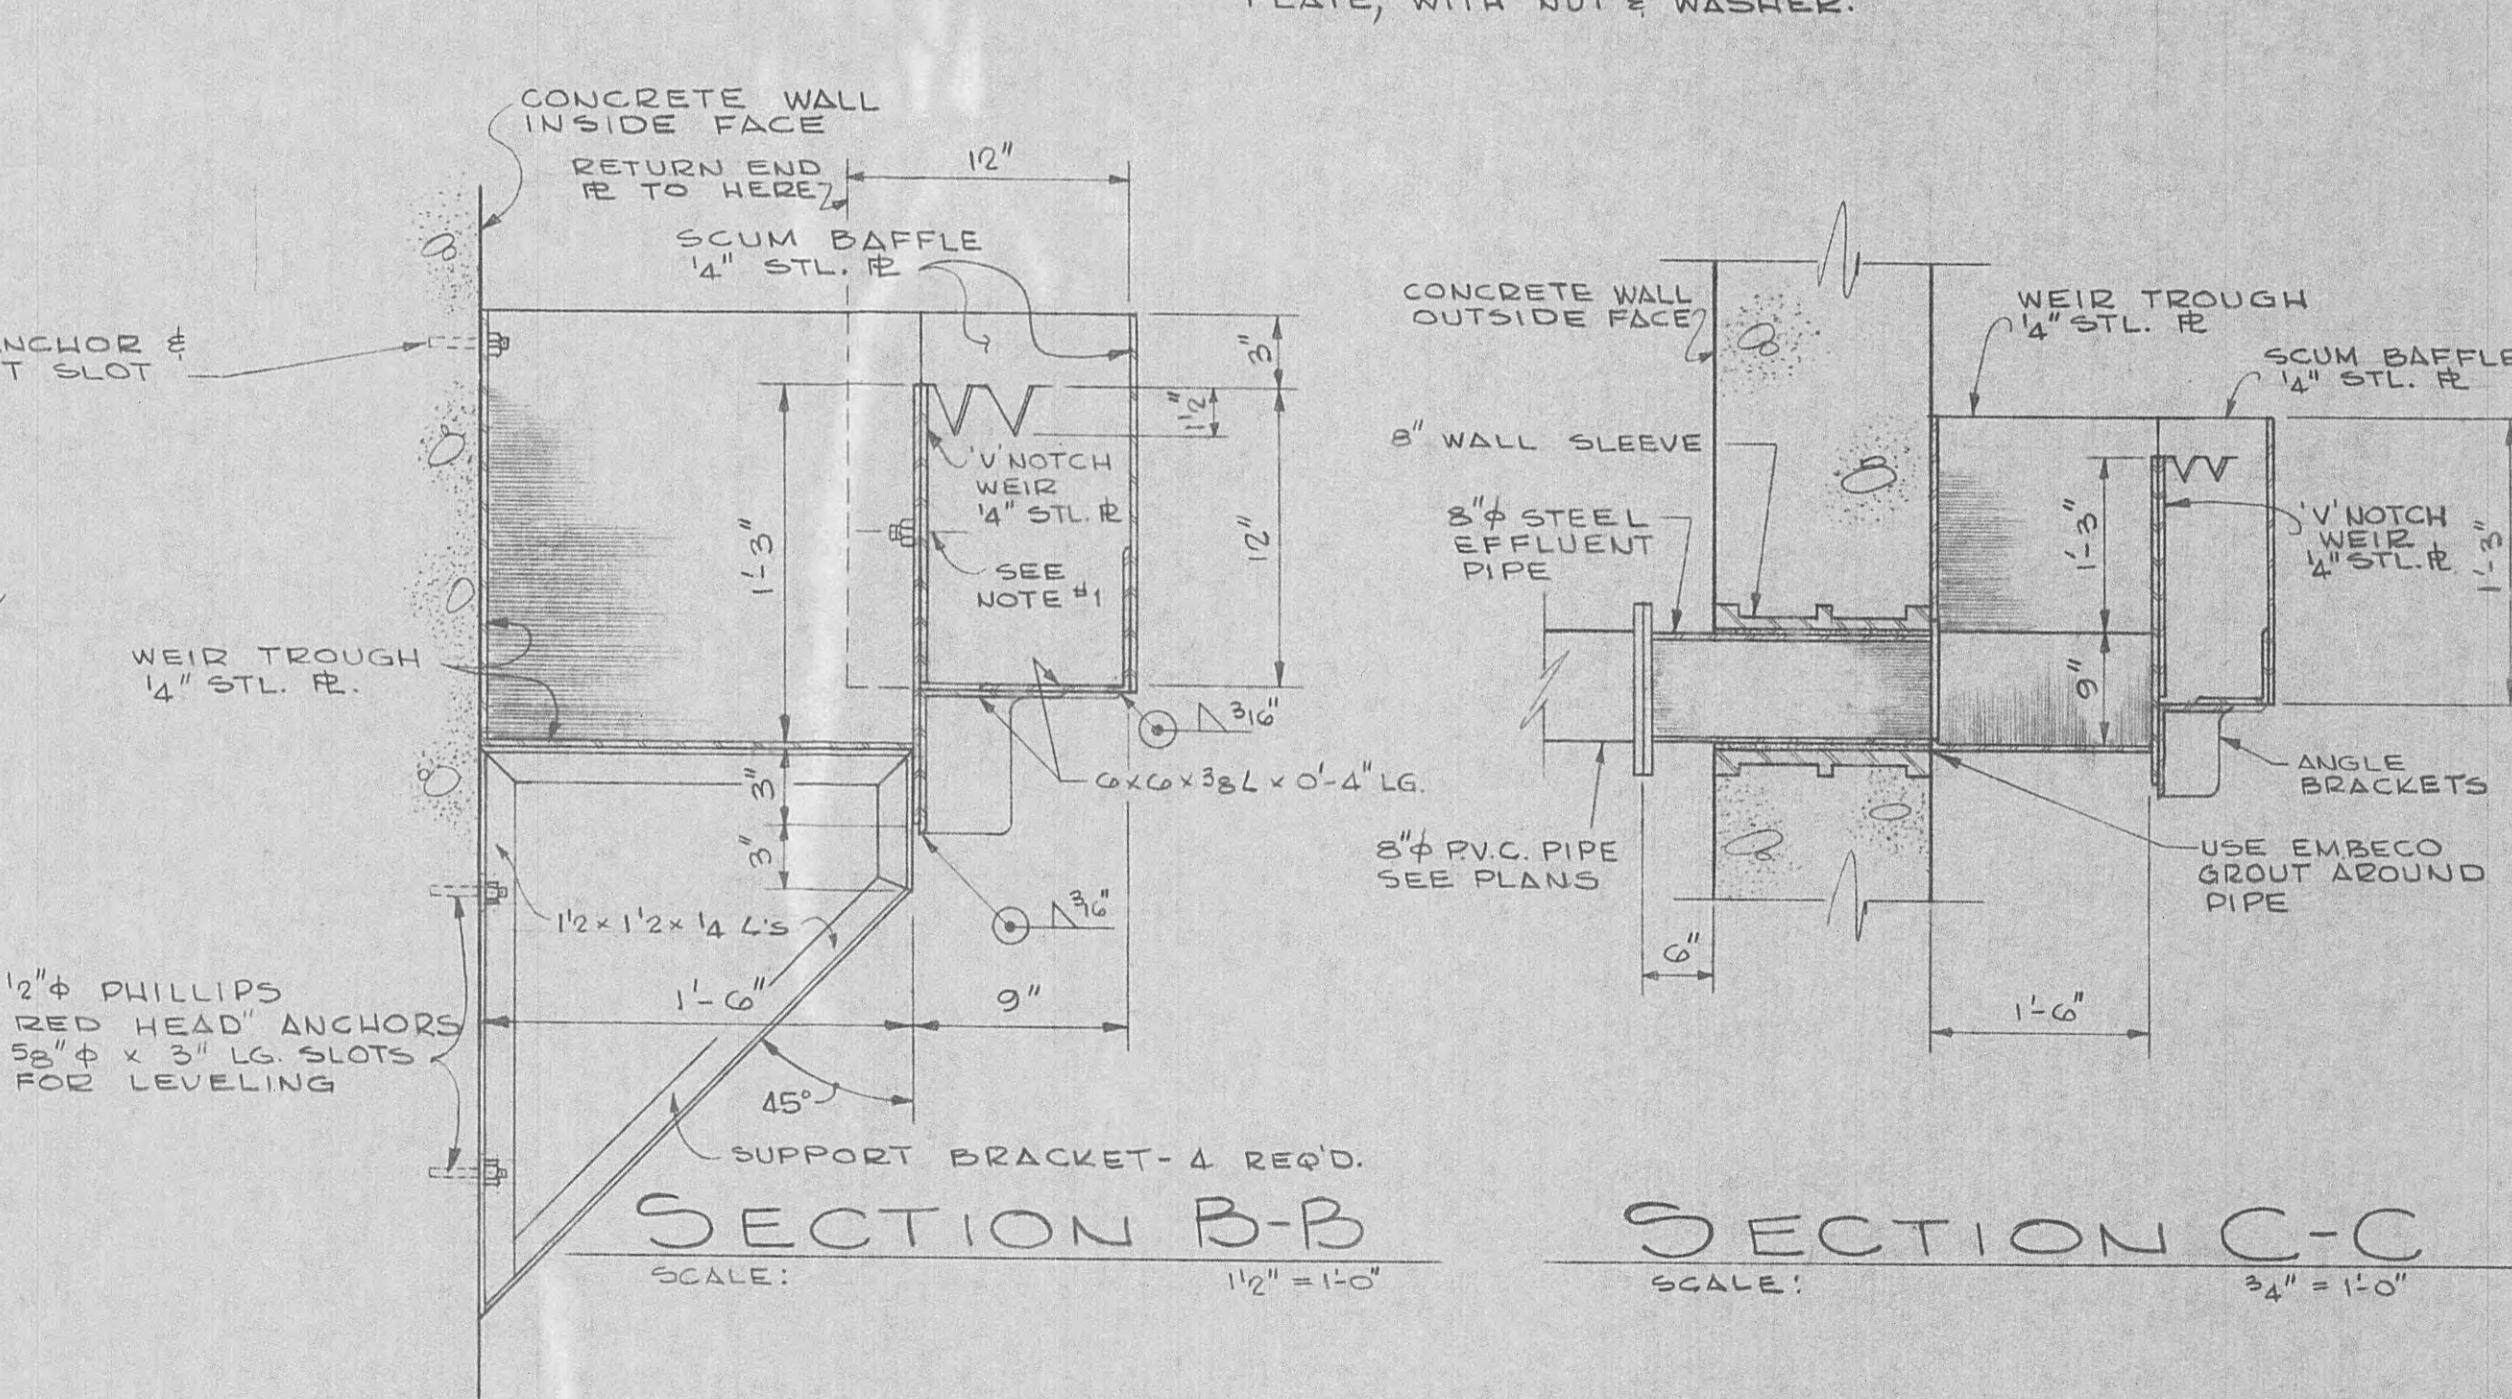

SECTION B-B
SCALE: $\frac{1}{2}'' = 1'-0''$


SECTION C-C
SCALE: $\frac{3}{4}'' = 1'-0''$

WEIR DETAILS FOR AERATION BASIN AS NOTED

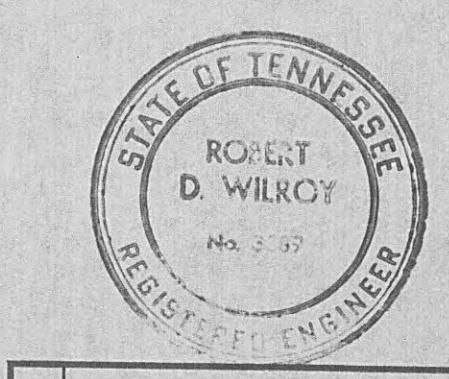

Pilot Wastewater Treatment Plant
FOR
HAZELMAN UTILITY BOARD
TENNESSEE
BLACK, CROW AND EIDNESS, INC.
ENGINEERS
ATLANTA GAINESVILLE GEORGIA
DRAWN BY: MERRILL FILE NO.: 484-63-1
CHECKED BY: TDR DATE: JUNE '69
REGISTERED ENGINEER
SHEET NO. 21
OF 26


| NO. | DESCRIPTION | DATE |
|-----|--------------|------------------------|
| | WEIR DETAILS | M-11 OF 15 OF 26 |

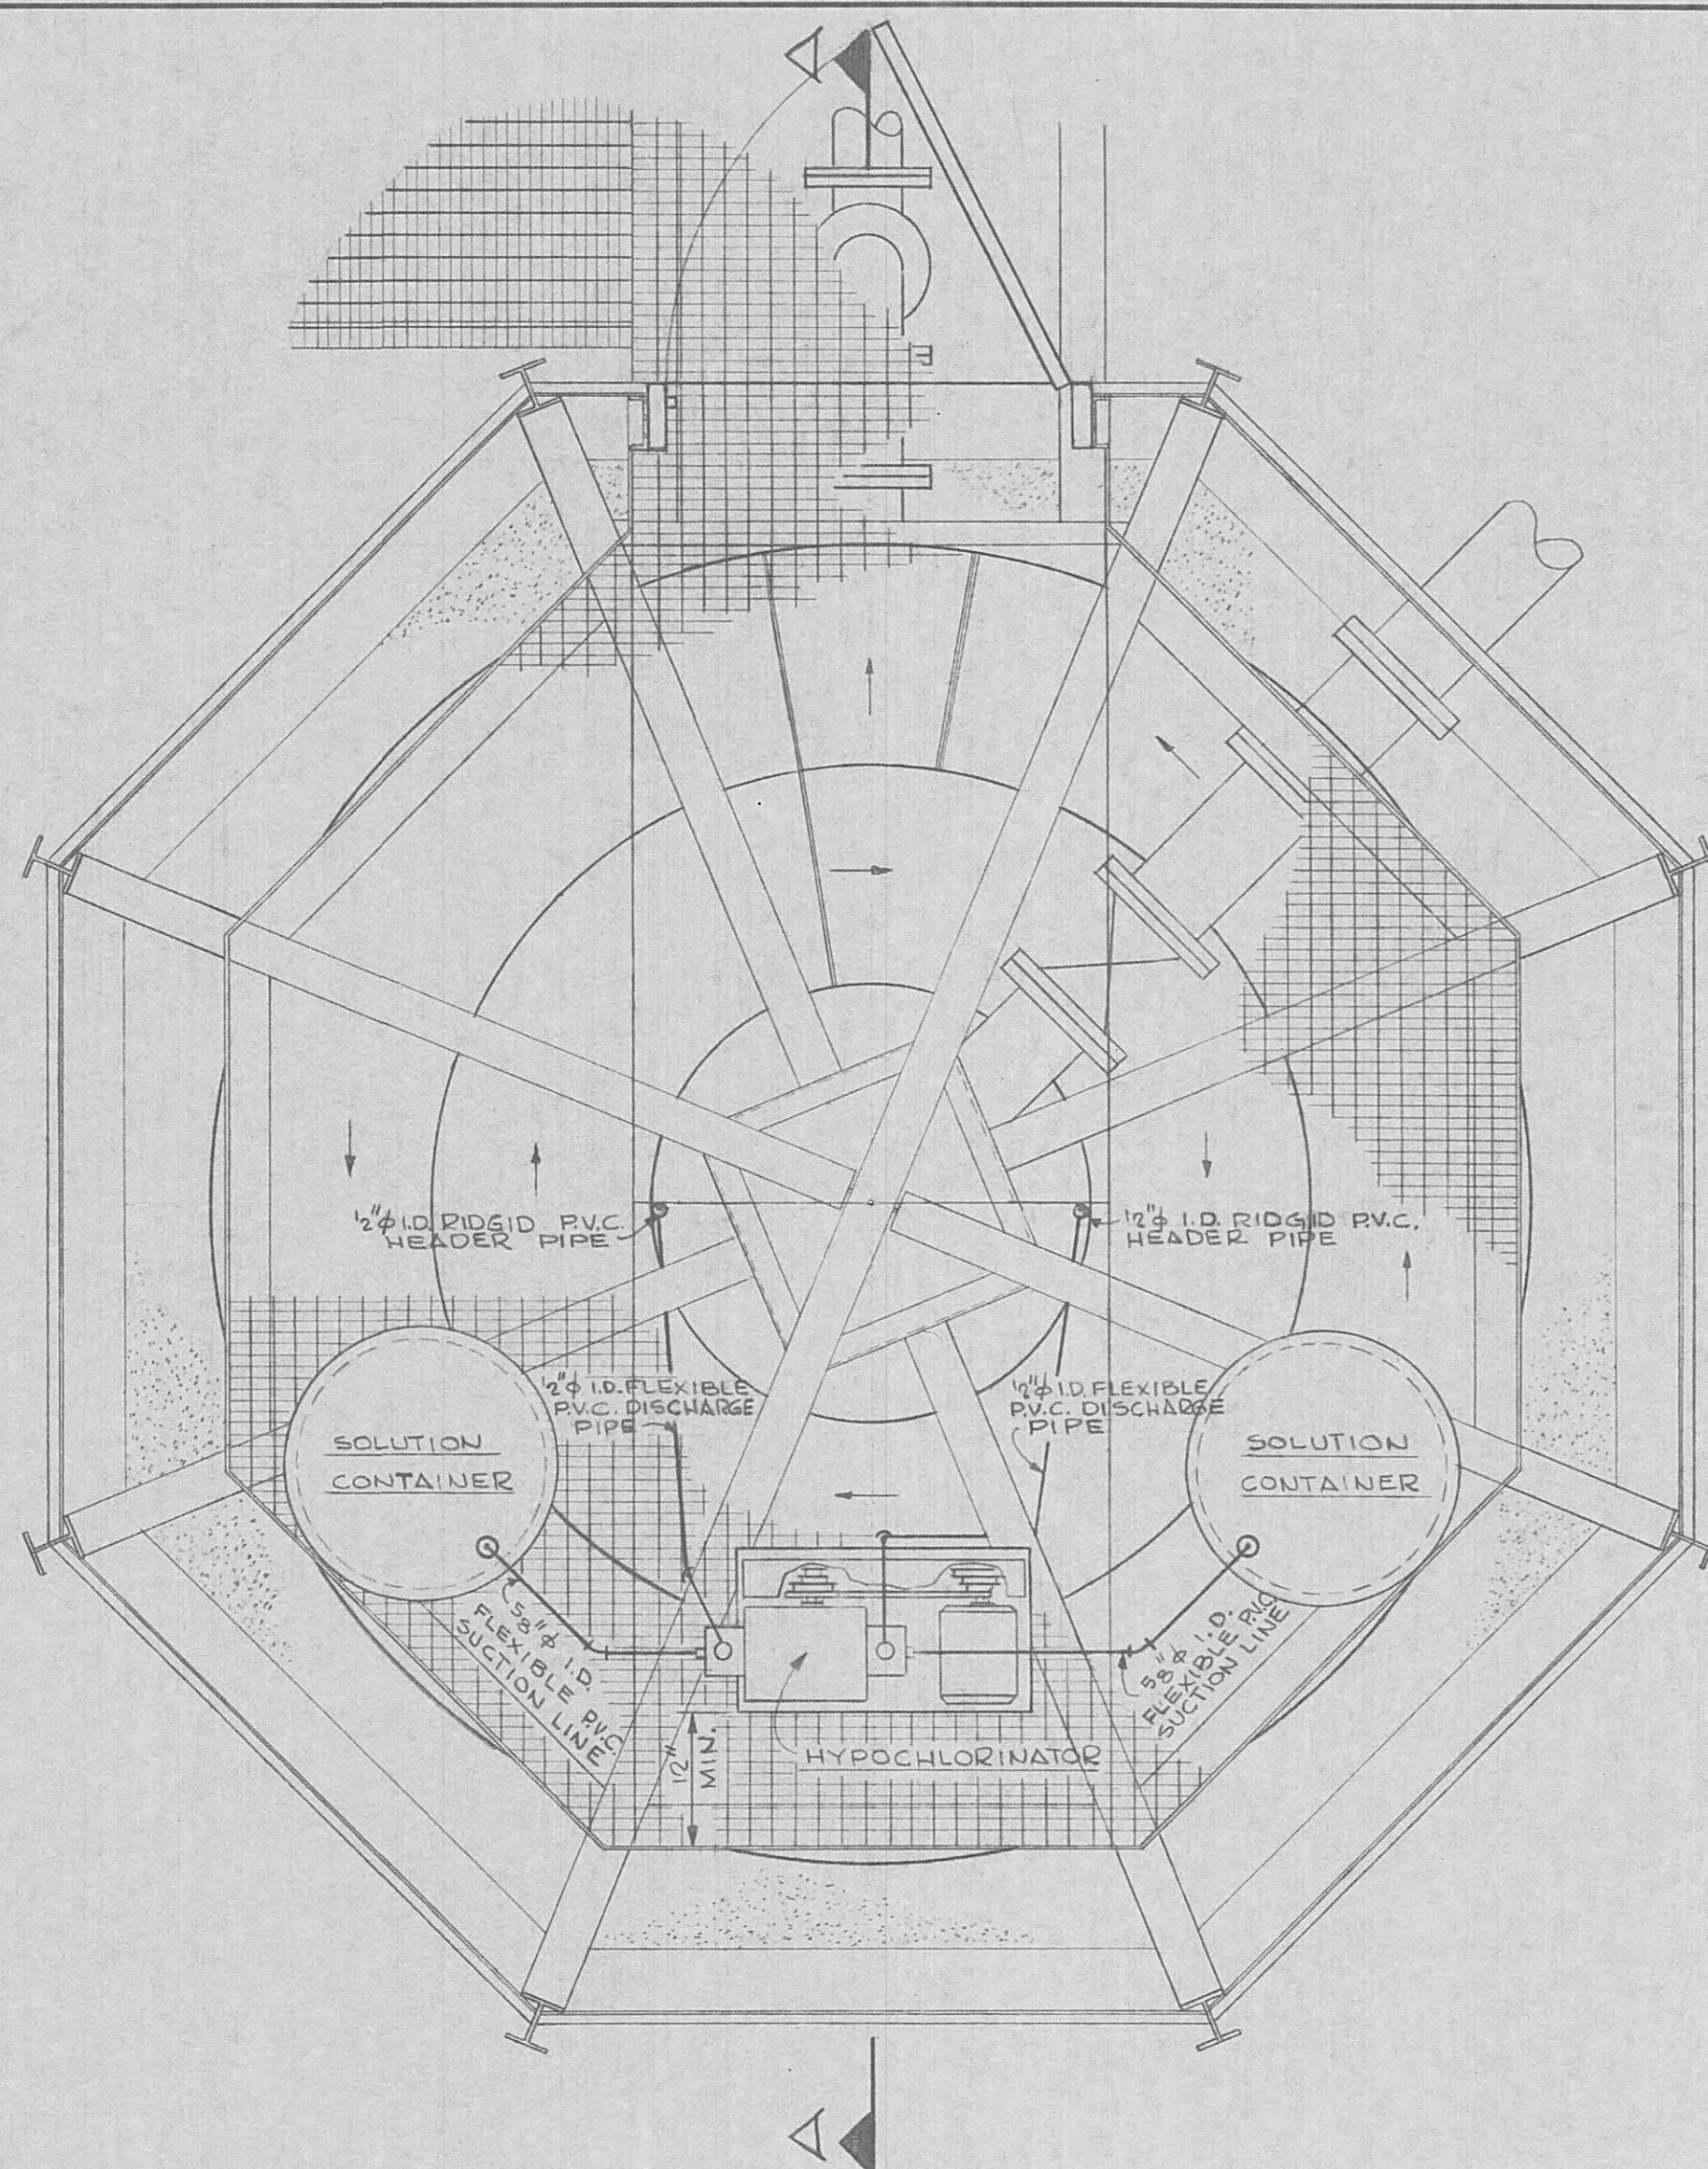

DIAZ ΔT FLOOR LEVEL


SCAL

$$\frac{3}{4}'' = 1\text{--}0''$$

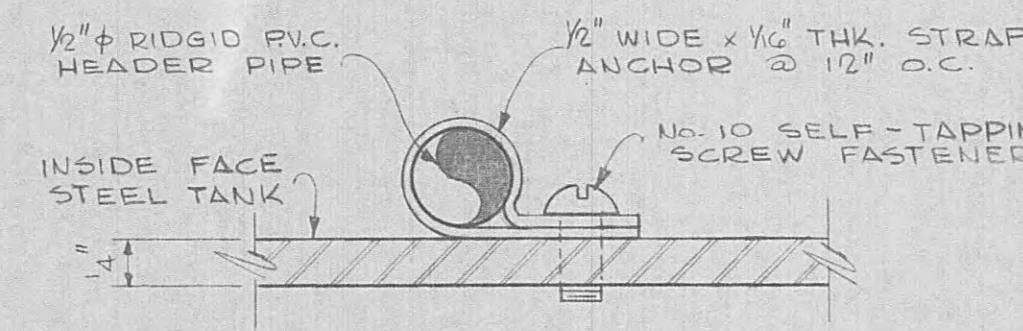


DETA

SCALE: FULL SIZE

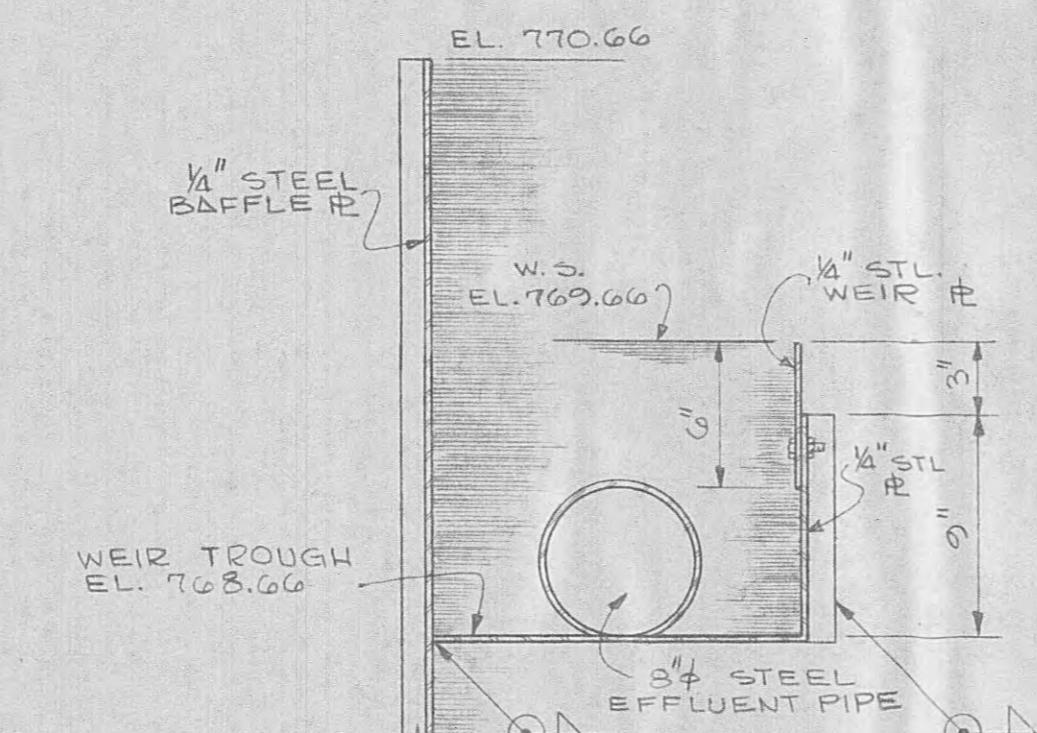


ELEVATION OF WEIR TROUGH
AT EFFLUENT OPENING

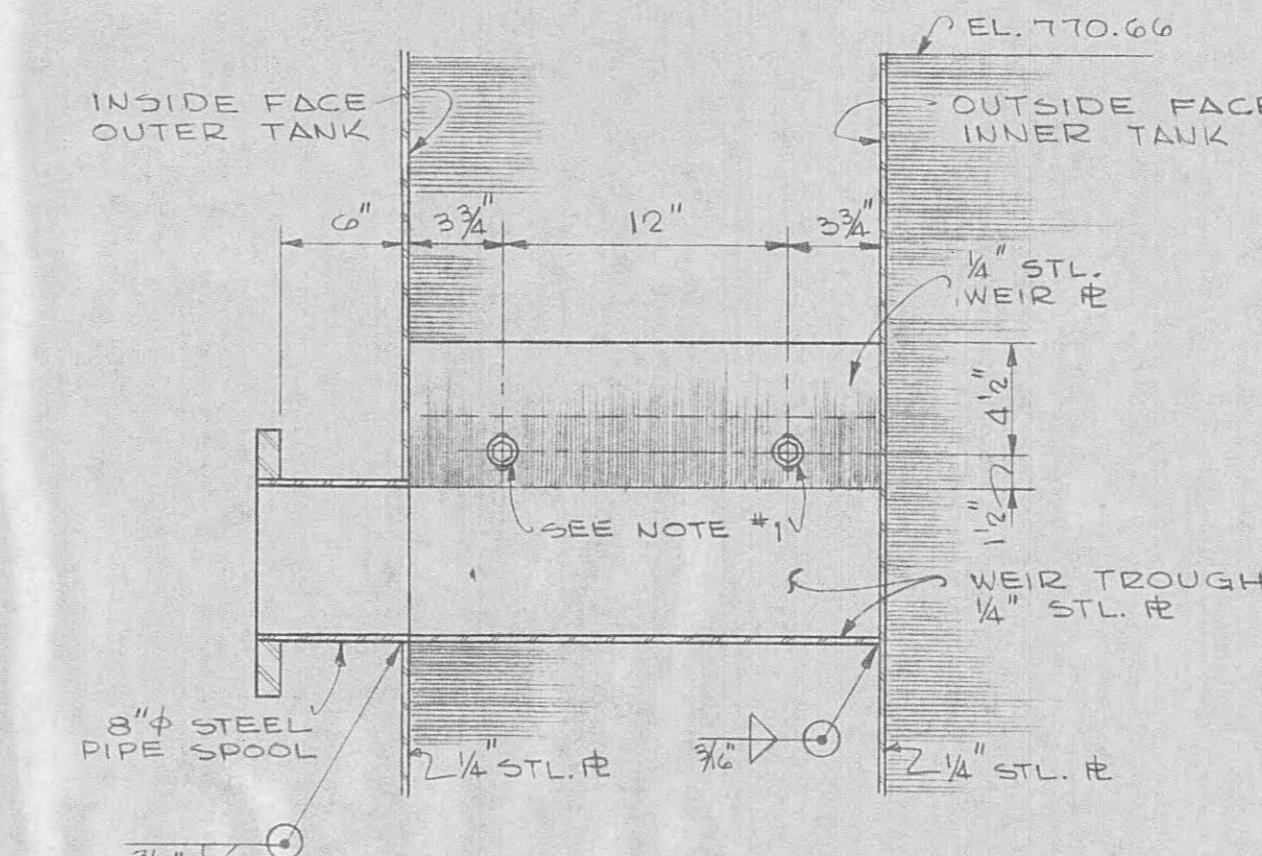


ELEVATION OF WEIR TROUGH





SCALE:

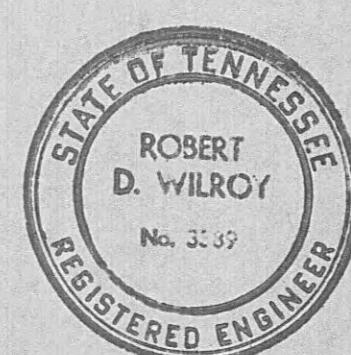


PILOT WASTEWATER TREATMENT PLANT
 FOR
 HARRIMAN UTILITY BOARD
 HARRIMAN TENNESSEE
 BLACK, CROW AND EIDSNESS, INC.
 ATLANTA ENGINEERS GEORGIA
 GAINESVILLE FLORIDA
 DRAWN BY: MERROW DATE: JUNE '69
 CHECKED BY: TDR FILE NO. 484-69-1

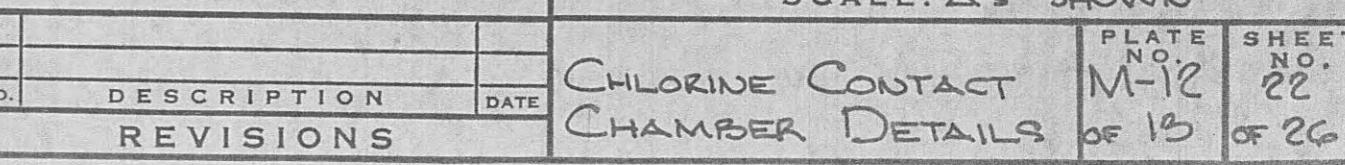

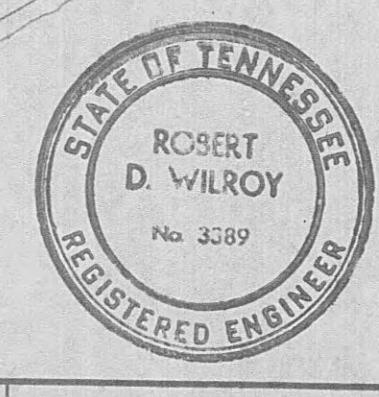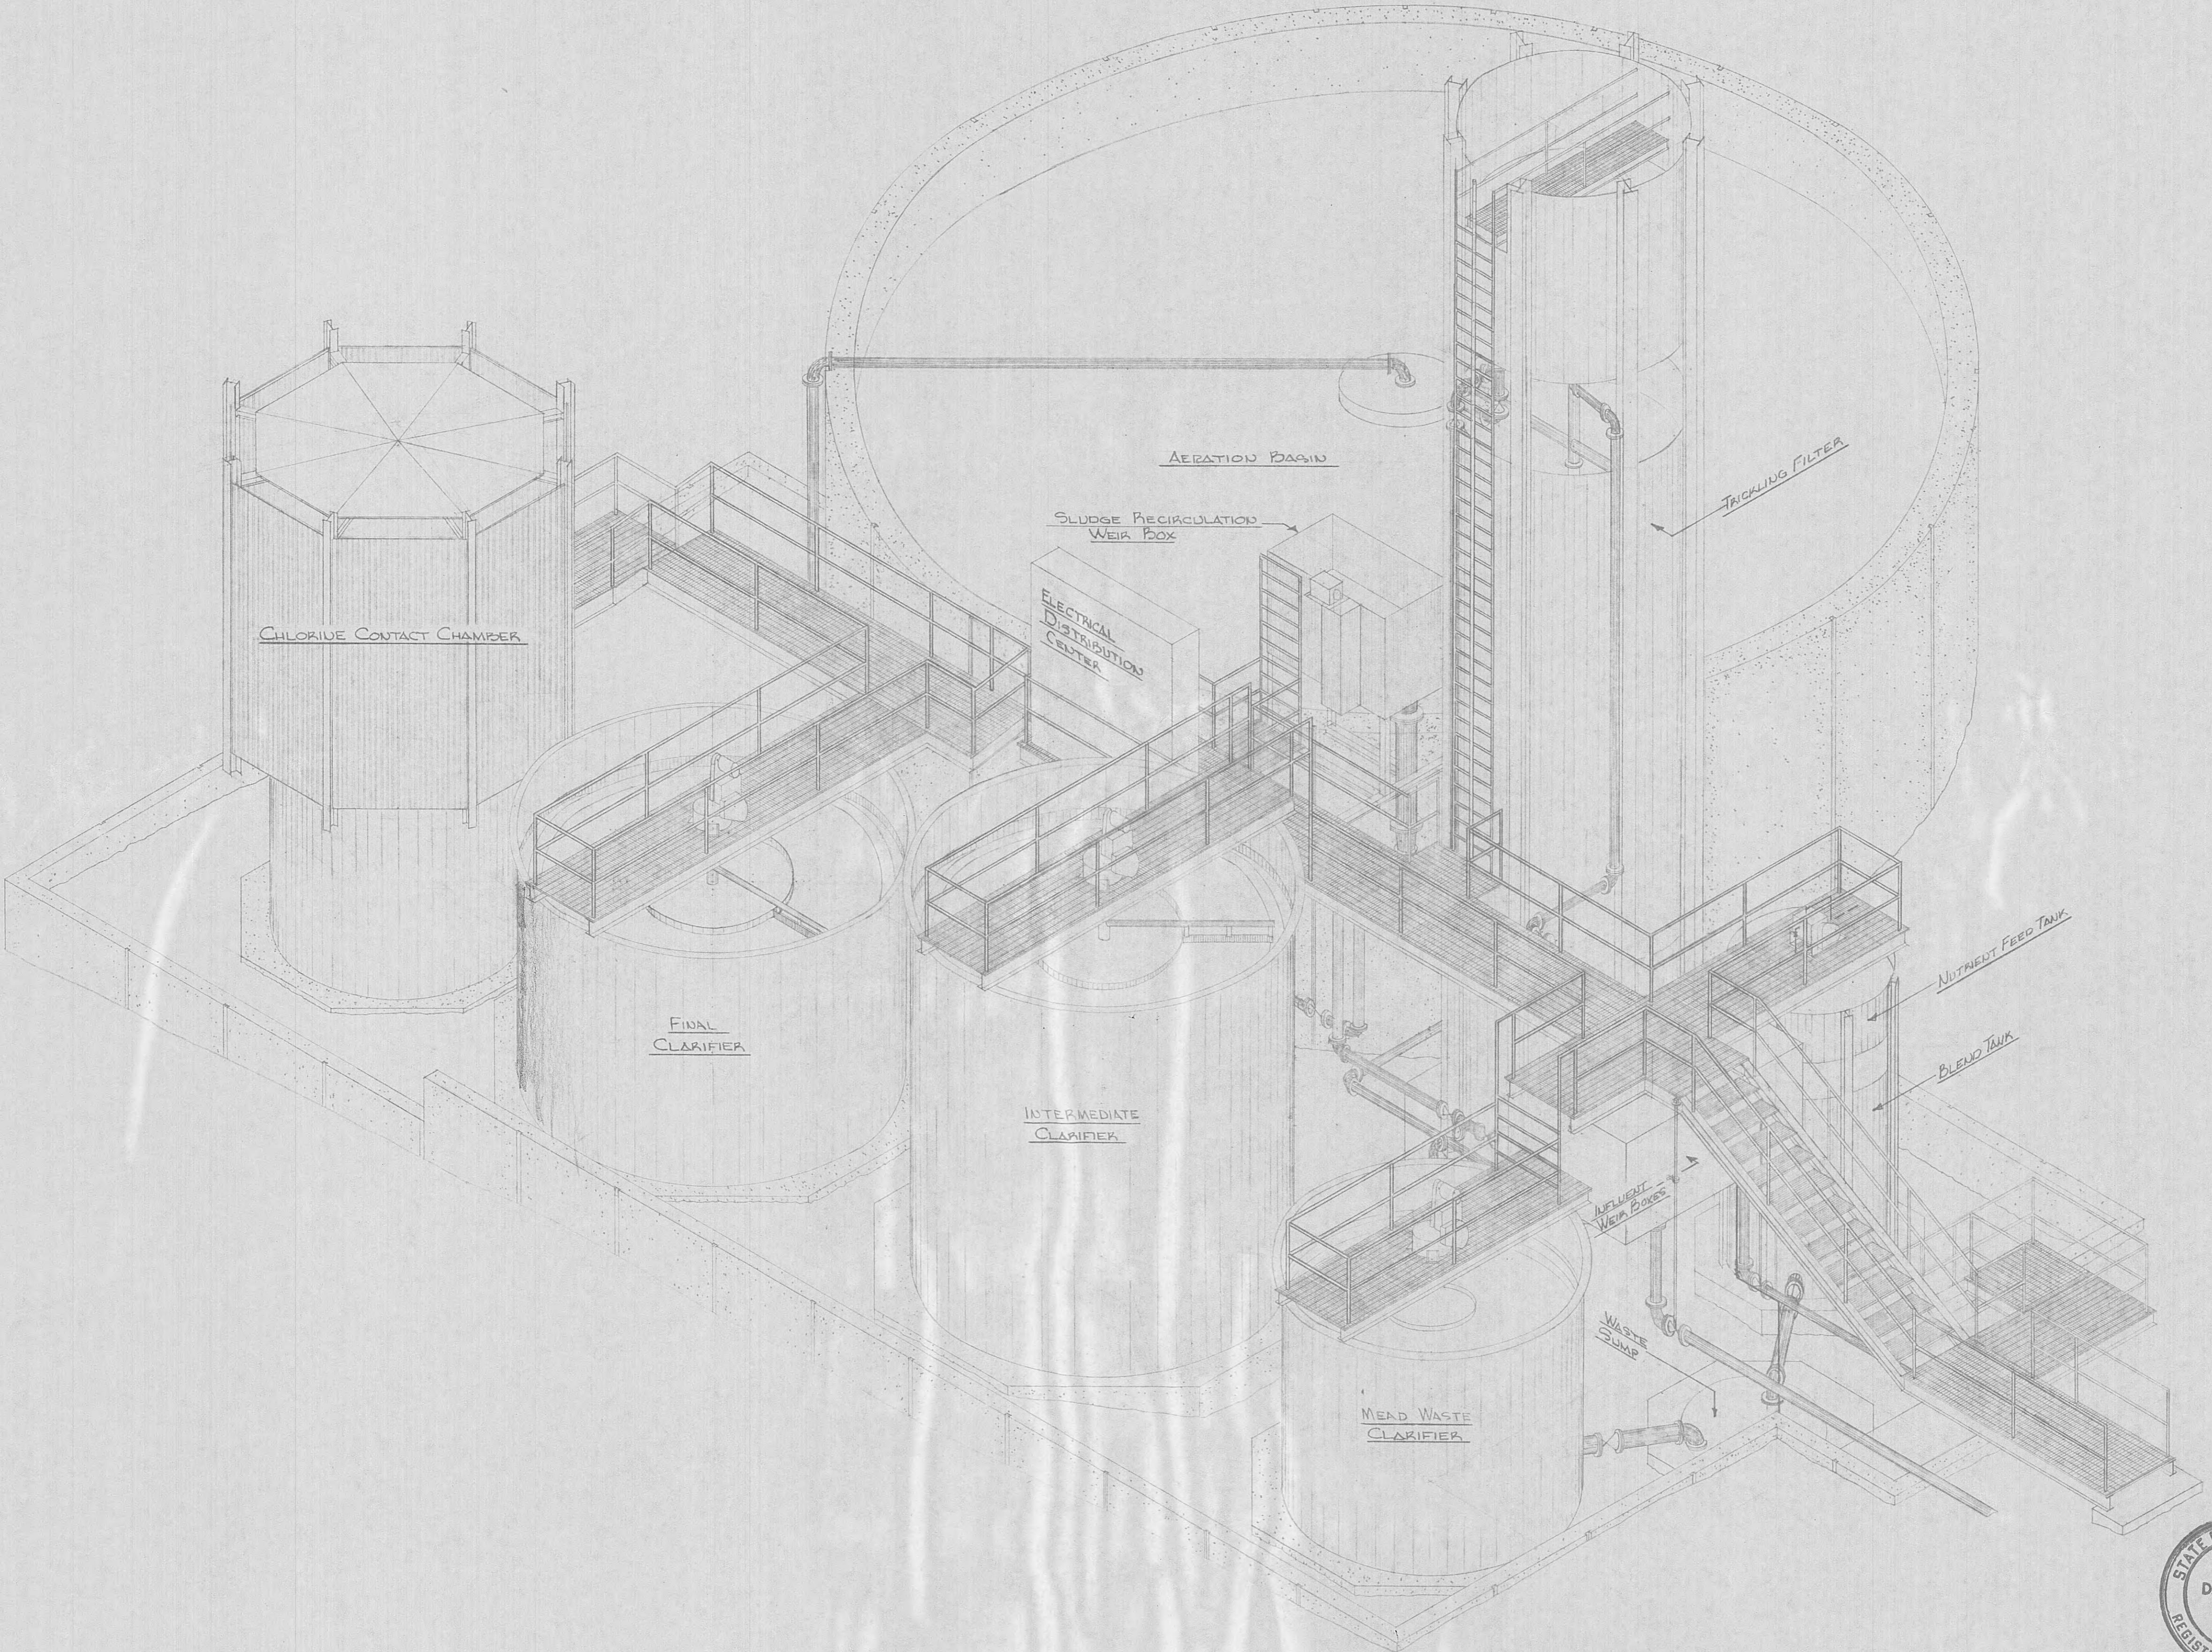

Pilot Wastewater Treatment Plant
FOR
HARRIMAN UTILITY BOARD
TENNESSEE
BLACK, CROW AND EIDNESS, INC.
ATLANTA GAINESVILLE GEORGIA FLORIDA
DRAWN BY: EDWARDS DATE: JUNE '69
CHECKED BY: TDR FILE NO. 404-691
SCALE: 1/4" = 1'-0"
PLANT ISOMETRIC PLATE NO. M-13 SHEET NO. 23
REVISIONS OF 15 OF 26

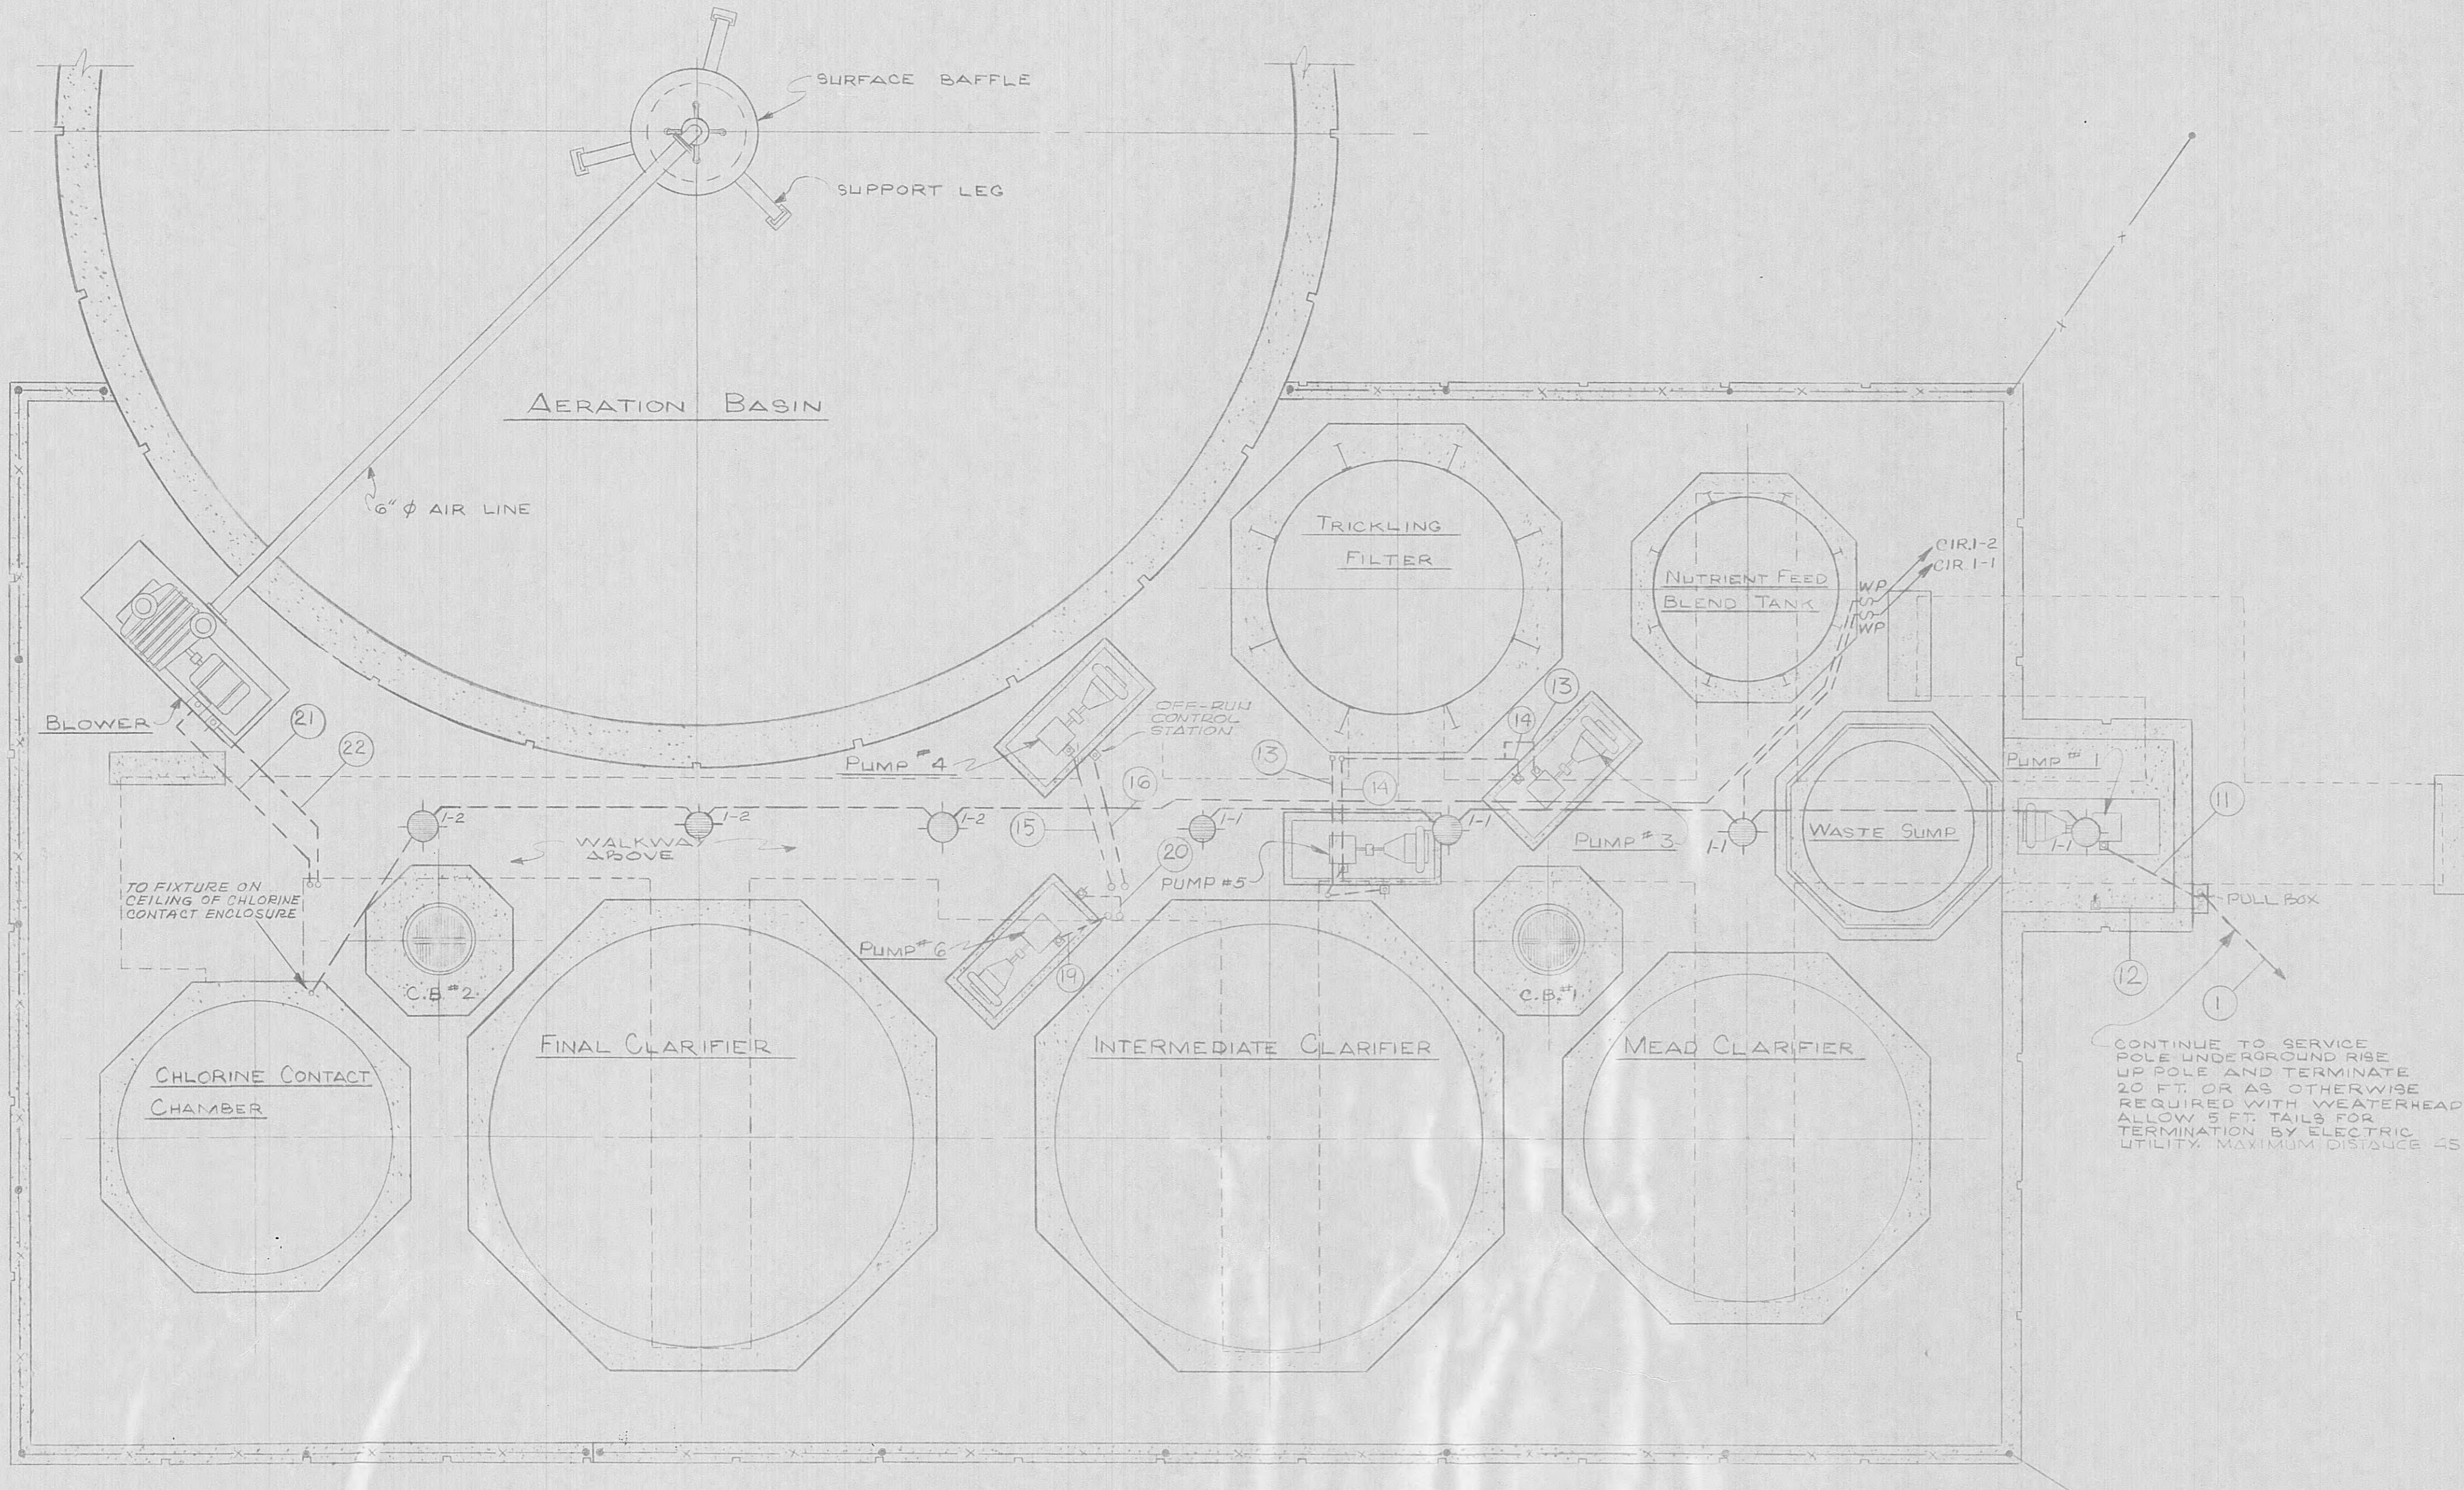

NOTE: FIXTURES INSTALLED
UNDER WALKWAY HALL
BY CYLINDRICAL NATIONAL
200 WATT AD SERIES
No. ADXF-22110

WIRING DIAGRAM BELOW OPERATING PLATFORM
SCALE $\frac{1}{4}'' = 15'$

Pilot Wastewater Treatment Plant
FOR
HARRIMAN UTILITY BOARD
TENNESSEE

ROBERT
D. WILROY
No. 3389
REGISTERED ENGINEER

BLACK, CROW AND EIDSNESS, INC.
ATLANTA GAINESVILLE GEORGIA
FLORIDA


DRAWN BY: BORELLA DATE: JUNE '65
CHECKED BY: FILE NO. 484-60-1

SCALE: AS SHOWN

| | | |
|-----------|-------------|------|
| NO. | DESCRIPTION | DATE |
| REVISIONS | | |


WIRING DIAGRAM BELOW
OPERATING PLATFORM

FILE NO. E-1 SHEET
22 OF 26

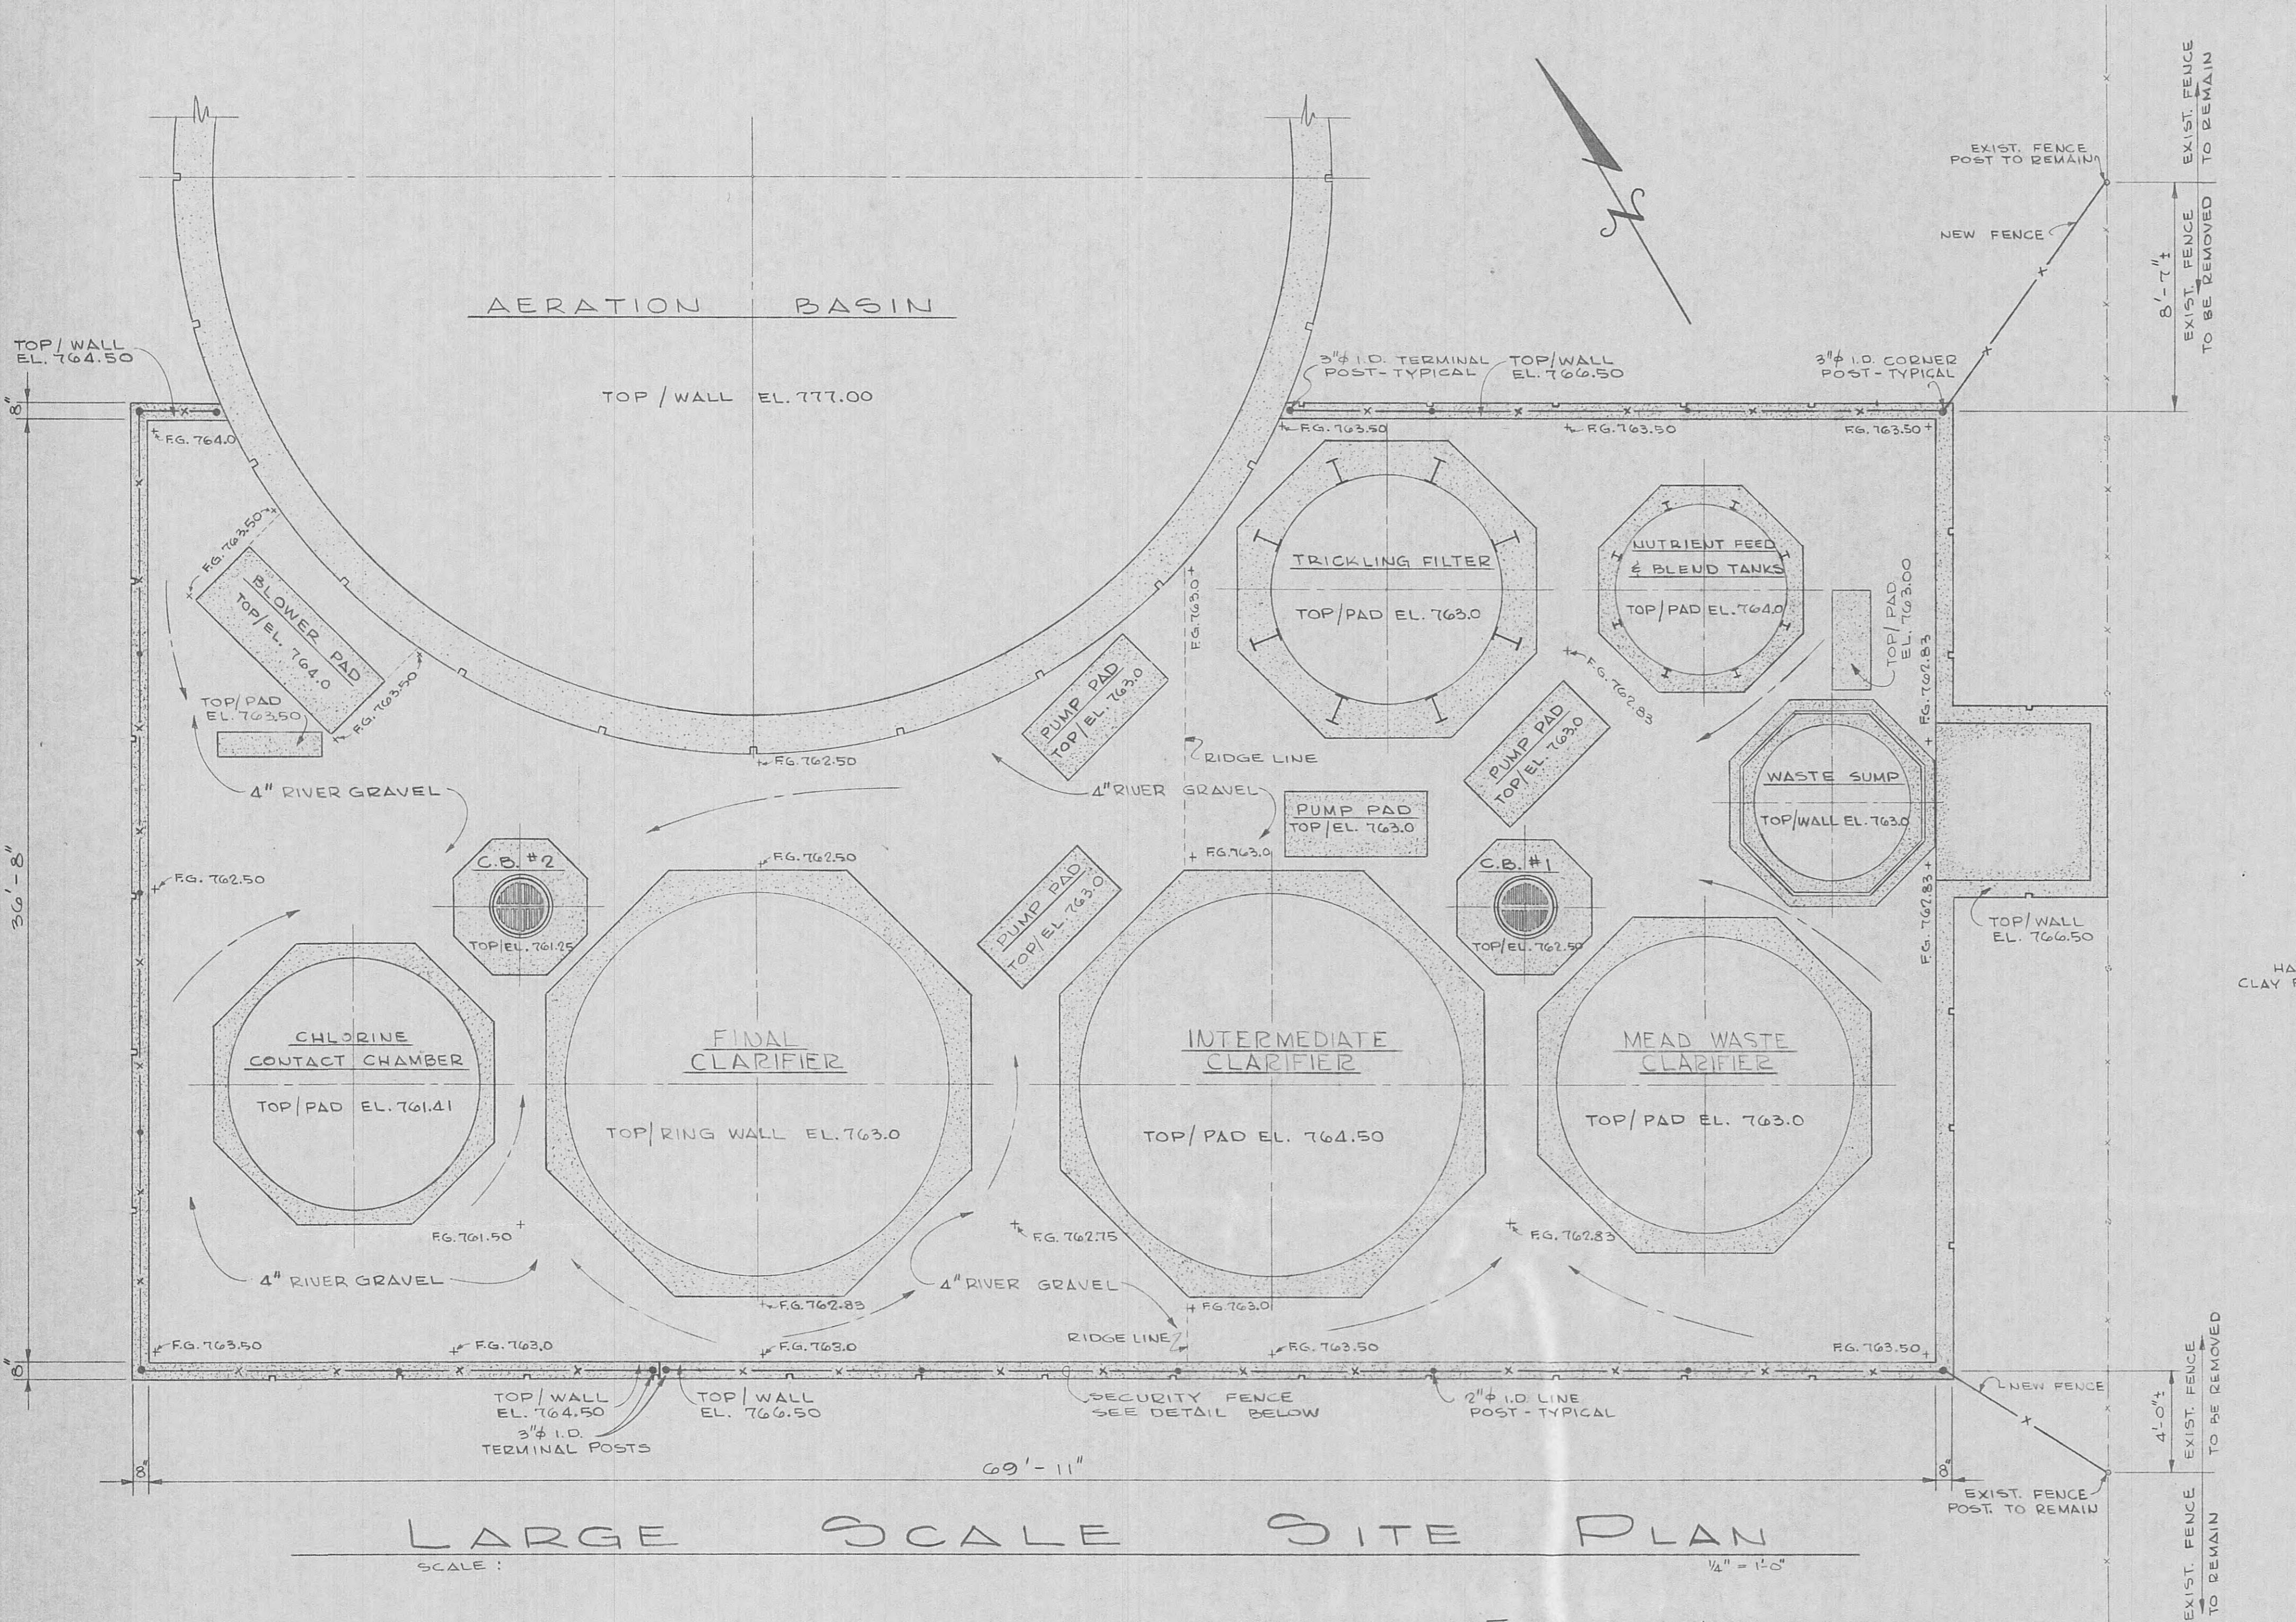

LARGE SCALE SITE PLAN

SCA

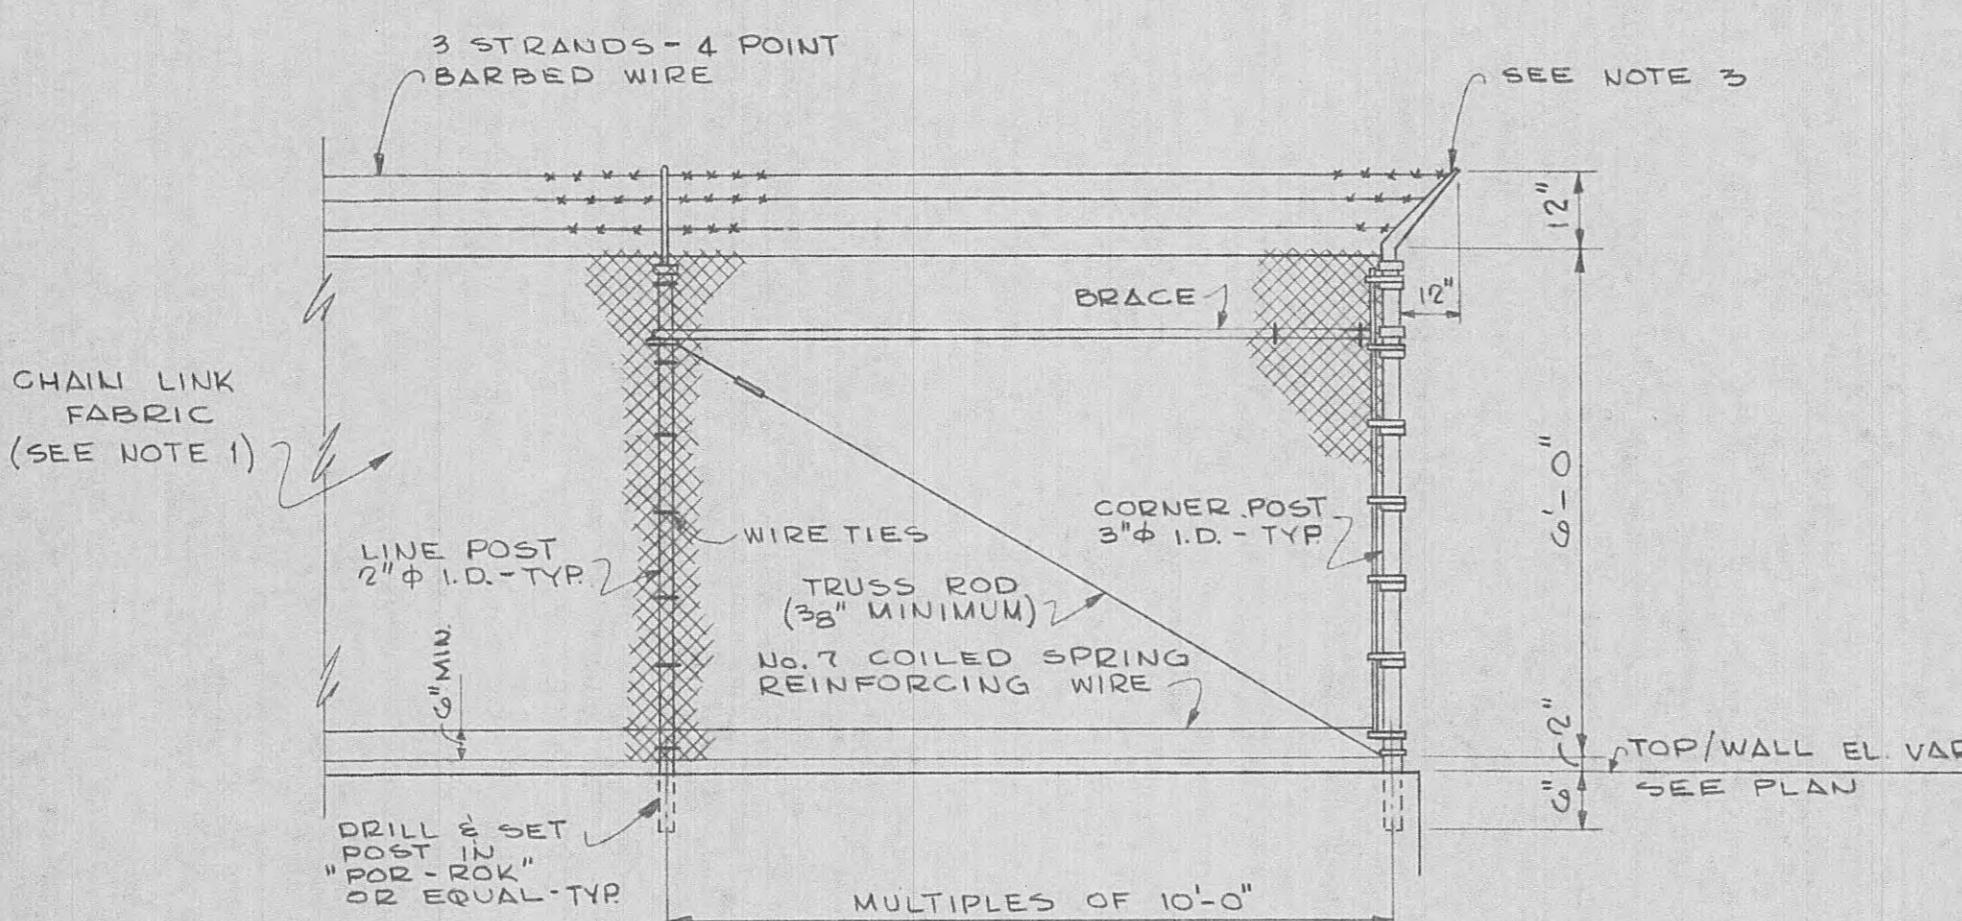


TYPICAL FENCE DETAILS


NO SCA


FENCE NOTES

1. ALL FABRIC TO BE #6 GAGE WIRE (0.192") WOVEN IN A 2" MESH. TOP AND BOTTOM EDGES TO BE TWISTED AND BARBED.
 2. HEIGHT OF FENCE TO BE 6'-0", WITH 3 STRANDS OF 4 POINT BARBED WIRE SECURELY ATTACHED TO SINGLE EXTENSION ARMS ALONG TOP OF FENCE, TOP STRAND TO BE 12" ABOVE.
 3. SINGLE EXTENSION ARM SHALL POINT OUTWARD AT AN ANGLE OF 45°. ALL EXTENSION ARMS TO BE 12 GAGE PRESSED STEEL.
 4. IN EARTH AREA THE CONTRACTOR SHALL PROVIDE NECESSARY GRADING AT LEAST 4' EACH SIDE OF FENCE TO INSURE GRADE LINE MEETING THE REQUIREMENTS FOR A 2" CLEARANCE.

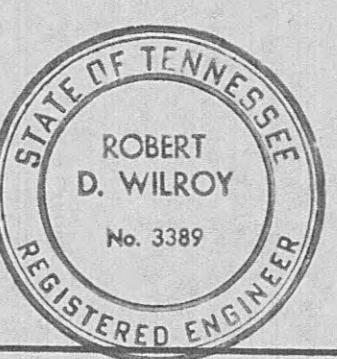


| | | |
|---|--------------------------------------|----------------------------|
| PILOT WASTEWATER TREATMENT PLANT FOR HARRIMAN UTILITY BOARD HARRIMAN TENNESSEE | | |
| BLACK, CROW AND EIDSNESS, INC. | | |
| ATLANTA GAINESVILLE | ENGINEERS | GEORGIA FLORIDA |
| DRAWN BY: MEAROW CHECKED BY: TDR | DATE: JUNE '69 FILE NO.: 484-69-1 | |
| SCALE: AS SHOWN | | |
| LARGE SCALE SITE PLAN & DETAILS | PLATE NO. P-3 OF 4 | SHEET NO. 3 OF 26 |


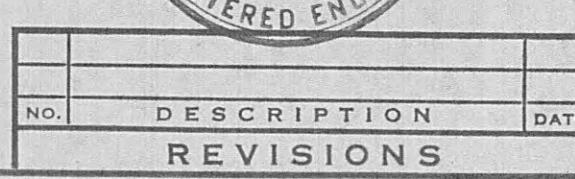


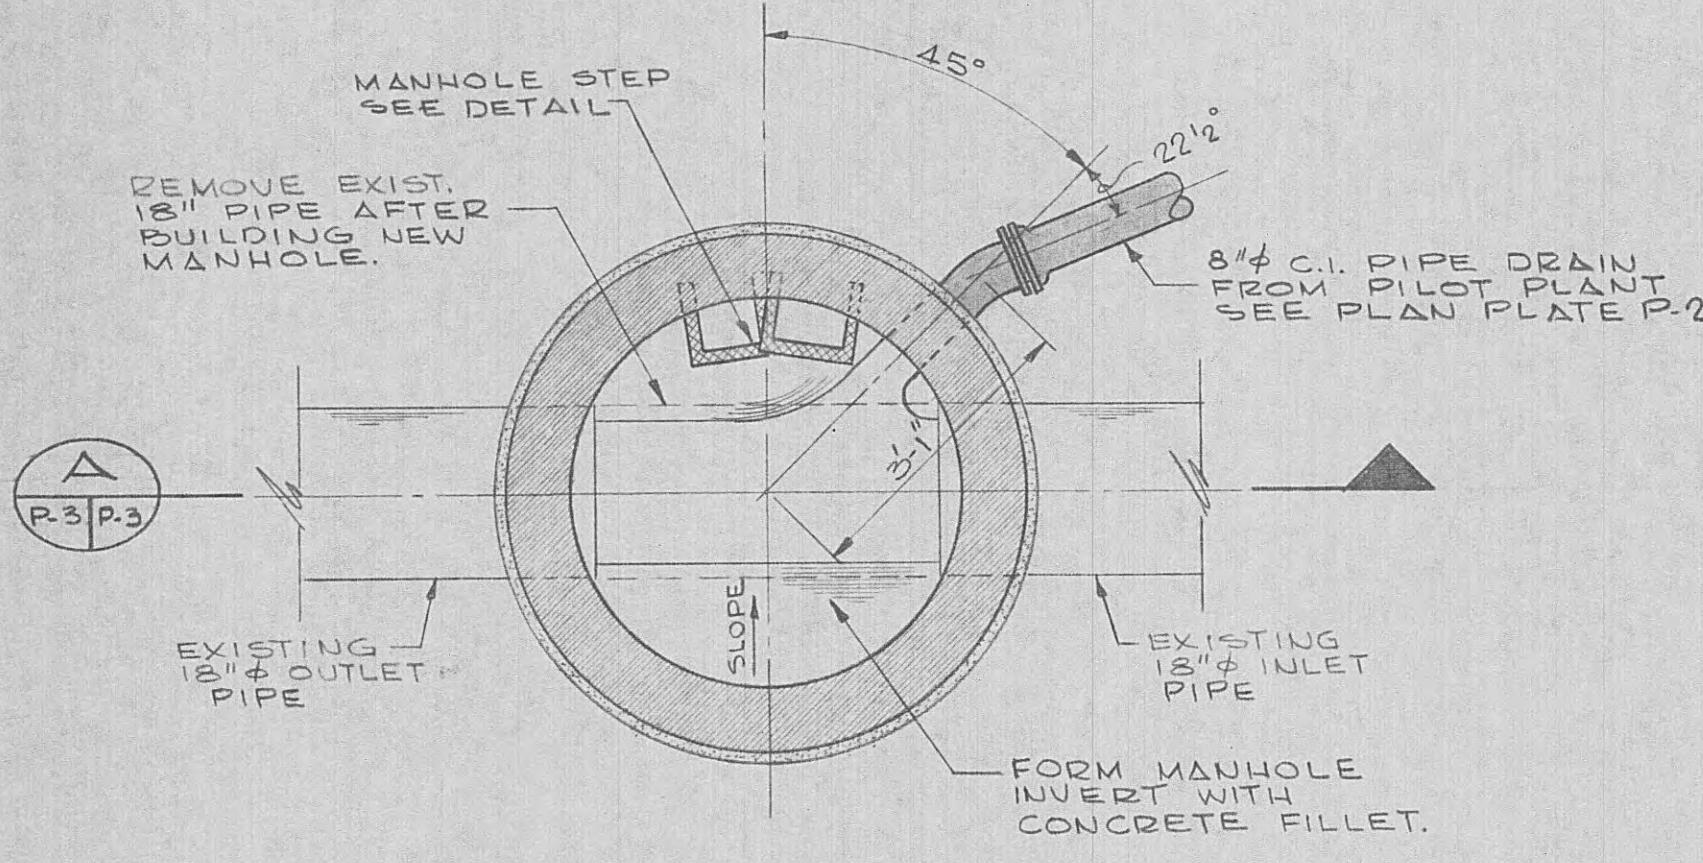

PLAN BELOW CORBEL

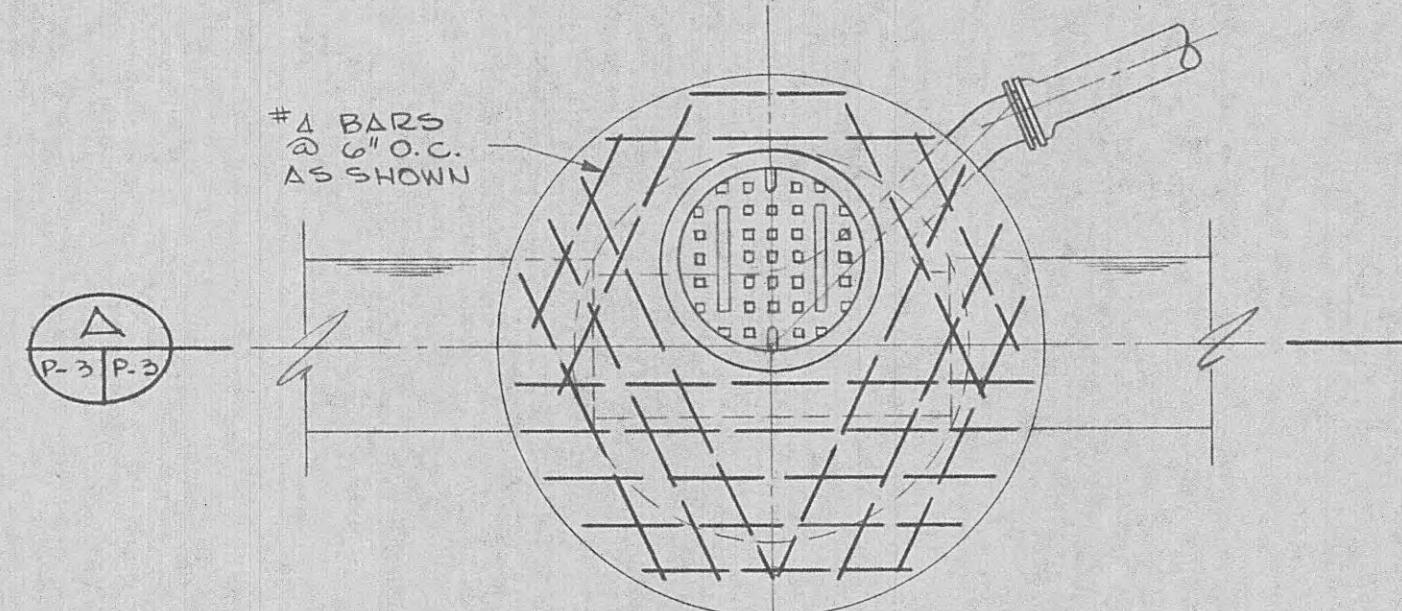



PLAN

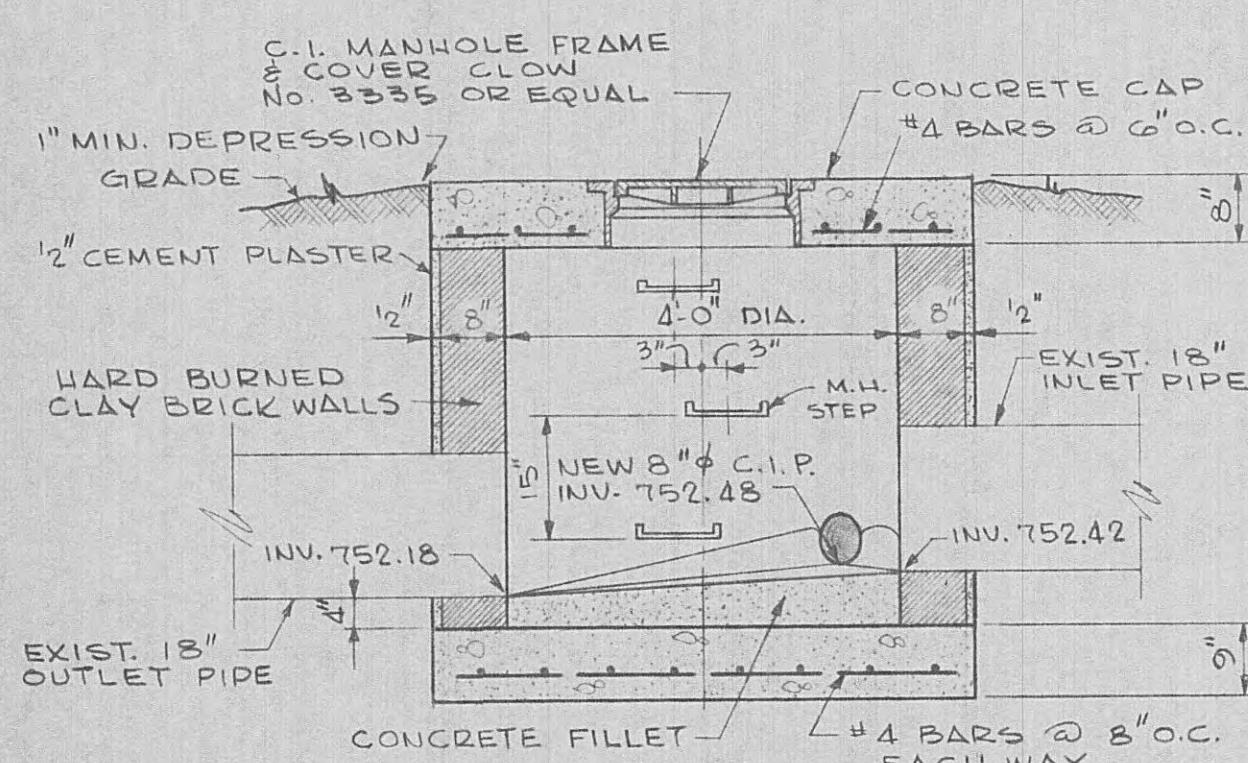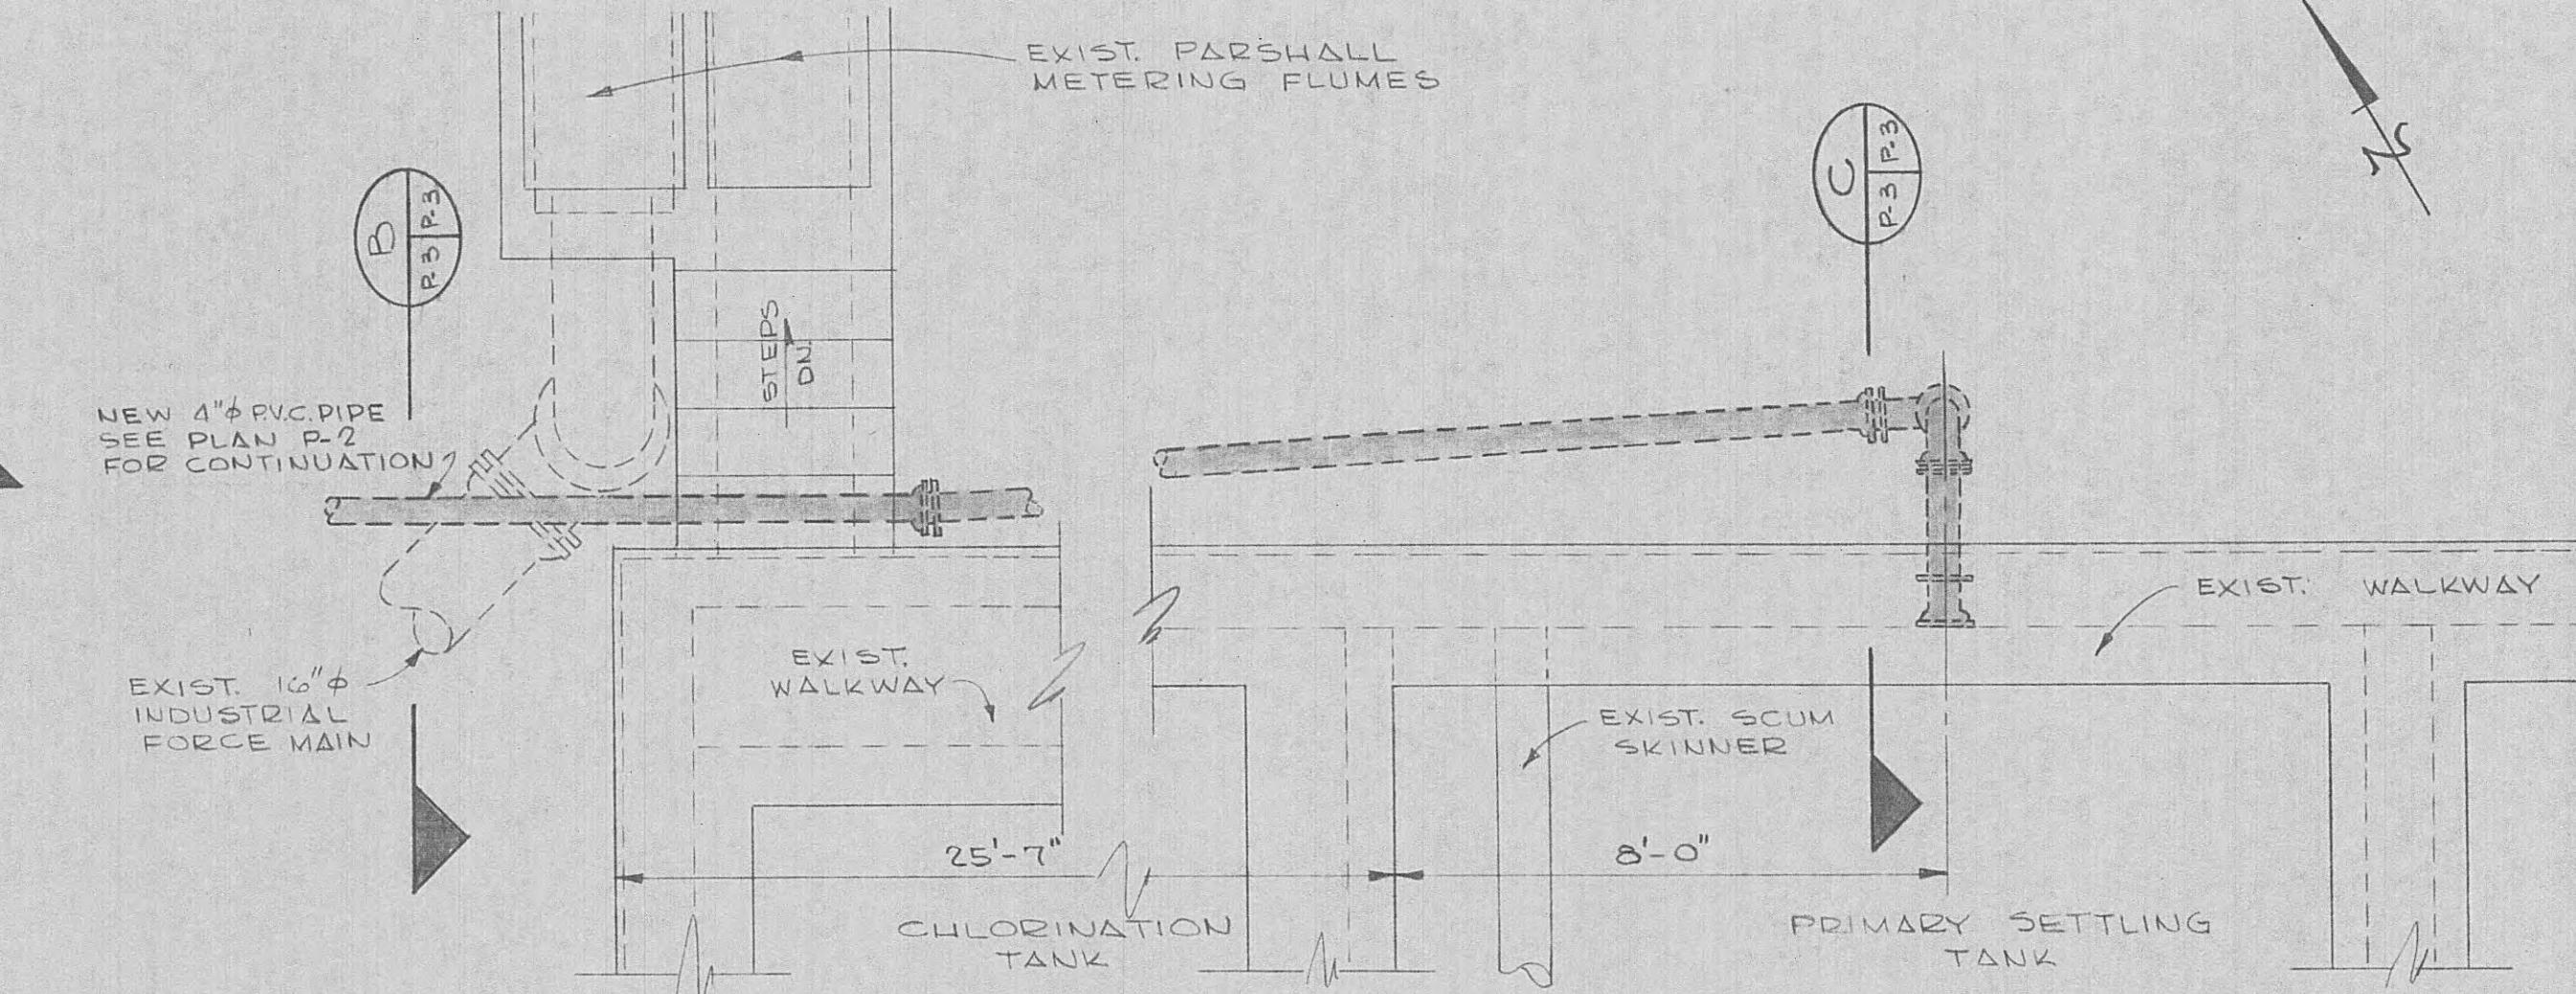

SECTION


MANHOLE STEP DETAIL

NO. 1/2" = 1'-0"

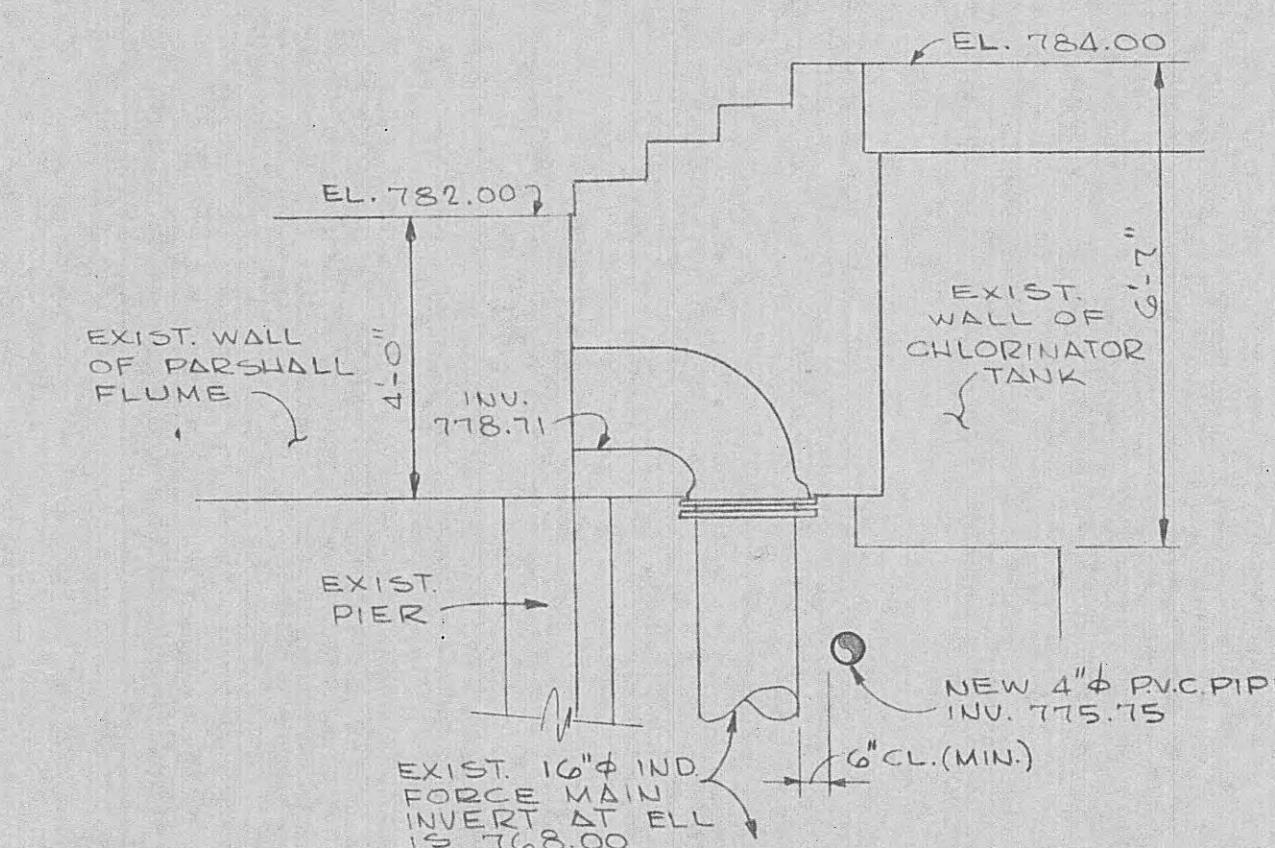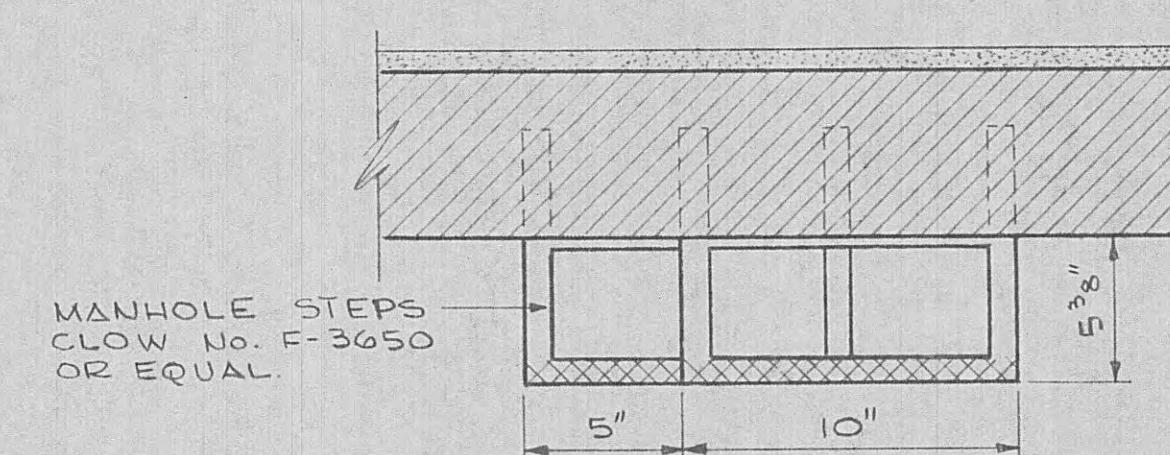

SECTION

PLAN

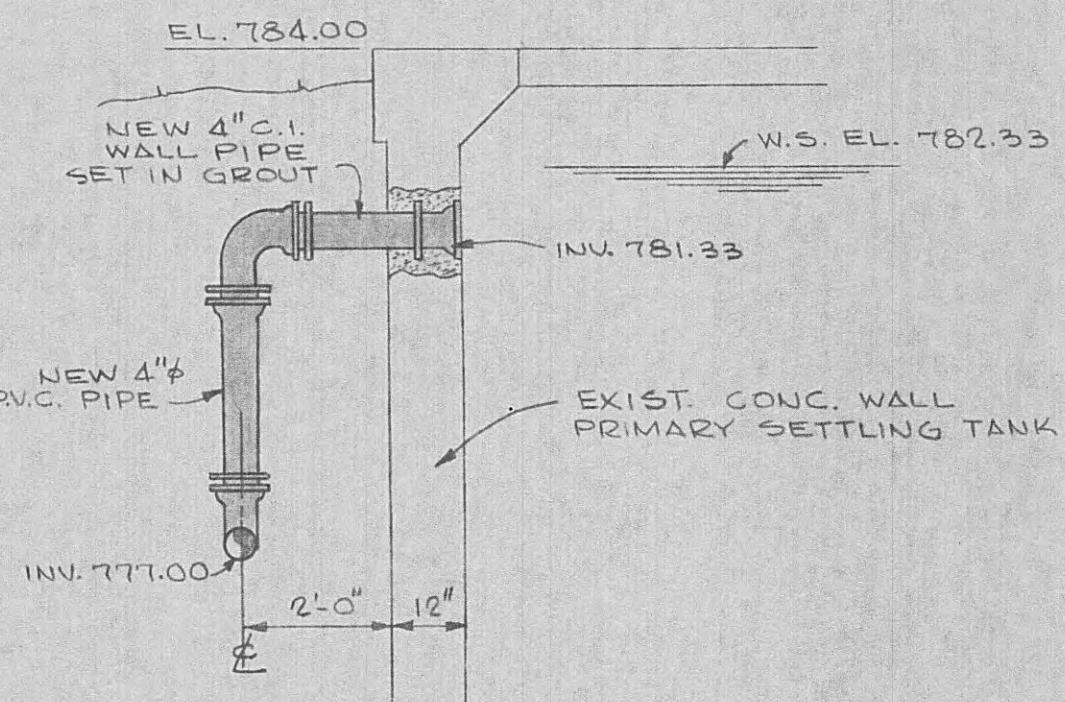


SECTION

C

MANHOLE DETAILS

SCALE:

NO. 1/2" = 1'-0"

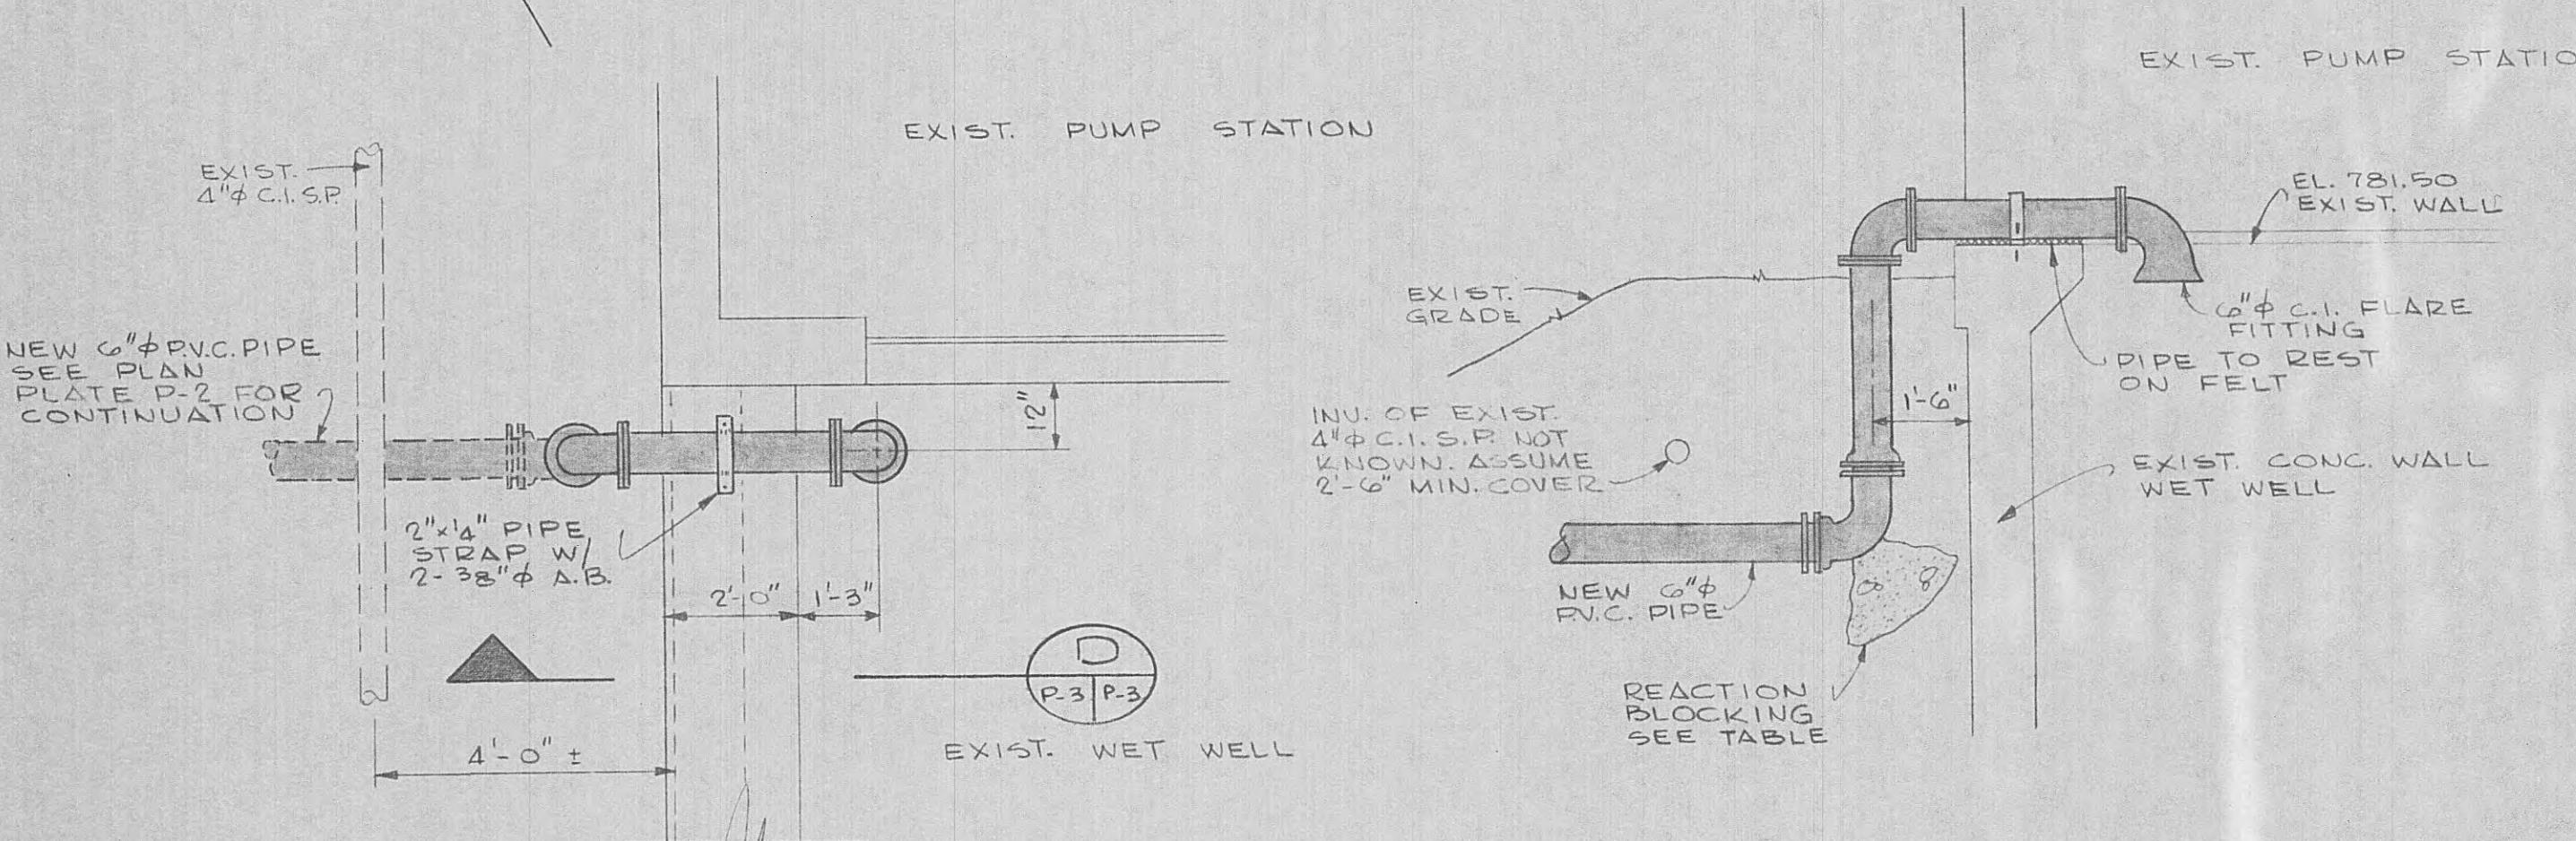

PLAN

SECTION

(D)

RETURN WASTE LINE DISCHARGE DETAIL

SCALE:

1/2" = 1'-0"

BEARING AREA TABLE (SQUARE FEET)

| PIPE SIZE | 90° BEND | 45° BEND | TEE |
|-----------|----------|----------|-----|
| 2" x 4" | 1.6 | 1.0 | 1.6 |
| 6" | 3.6 | 2.0 | 3.6 |

THE FIGURES IN THIS TABLE ARE BASED ON 3000 POUNDS PER SQUARE FOOT SOIL BEARING AGAINST UNDISTURBED TRENCH WALL AND ARE TO REPRESENT THE MINIMUM VERTICAL PROJECTED AREA OF THE REACTION BLOCK IN A PLANE PERPENDICULAR TO A LINE BISECTING THE INCLUDED ANGLE OF THE FITTING.

| | | |
|--|---|-----------------------|
| Pilot Wastewater Treatment Plant FOR HARRIMAN UTILITY BOARD HARRIMAN TENNESSEE | | |
| BLACK, CROW AND EIDNESS, INC. ATLANTA GEORGIA GAINESVILLE FLORIDA | | |
| ROBERT D. WILROY No. 3389 REGISTERED ENGINEER | DATE: JUNE '68 DRAWN BY: MERRILL CHECKED BY: TDR FILE NO. 484-69-1 | SCALE: AS SHOWN |
| NO. DESCRIPTION DATE | PLATE NO. P-4 SHEET NO. 4 OF 4 OF 26 | MISCELLANEOUS DETAILS |
| REVISIONS | | |

STRUCTURAL NOTES:

- CONCRETE MIX DESIGN & VERIFICATION TESTS SHALL BE CONDUCTED AT CONTRACTORS EXPENSE BY AN APPROVED INDEPENDENT LABORATORY IN ACCORDANCE WITH ACI STANDARD 613-54. ALL CONCRETE SHALL BE 3000 P.S.I. COMPRESSIVE STRENGTH AT 28 DAYS.

MIX DESIGN AND VERIFICATION TESTS SHALL BE SUBMITTED TO ENGINEER FOR APPROVAL.

REINFORCING STEEL SHALL BE DEFORMED BARS MEETING ASTM A-305-56T, NEW BILLET STEEL OR RAIL STEEL CONFORMING TO ASTM STANDARD A615. MIN. YIELD STRENGTH SHALL BE 60,000 P.S.I. ALL REINFORCING STEEL SHALL BE LAPPED 32 BAR DIAMETERS. AT WALL INTERSECTIONS, HORIZONTAL BARS SHALL BE PLACED TO PROVIDE A 32 BAR DIAMETER RETURN.

ALL WATERSTOPPS SHALL BE 8" x $\frac{1}{8}$ " CONT. STEEL PLATE.

ALL REINFORCEMENT SHALL BE PLACED IN ACCORDANCE WITH ACI 315-65 DETAILING MANUAL.

NO CONSTRUCTION JOINTS OTHER THAN THOSE SHOWN ON THE DRAWINGS WILL BE PERMITTED WITHOUT ENGINEERS APPROVAL.

ALL WALL AND SLAB OPENINGS TO HAVE 2- #5 x 3'-0" DIAGONAL BARS EACH SIDE OF OPENING.



ALL CONCRETE SHALL BE PLACED IN ACCORDANCE WITH ACI 318-63 "BUILDING CODE REQUIREMENTS FOR REINFORCED CONCRETE".

ALL STRUCTURAL STEEL SHALL BE FABRICATED, DESIGNED AND ERECTED IN ACCORDANCE WITH THE LATEST A.I.S.C. "SPECIFICATION FOR THE DESIGN, FABRICATION & ERECTION OF STRUCTURAL STEEL FOR BUILDINGS".

ALL STRUCTURAL STEEL SHALL MEET THE REQUIREMENTS OF AST.M. A-36.

ALL BOLTS SHALL MEET REQUIREMENTS OF AST.M. A 325.

UNLESS NOTED OTHERWISE ALL CONNECTIONS SHALL BE FRAMED BEAM CONNECTION PER TABLE I OF AISC SPECIFICATIONS.

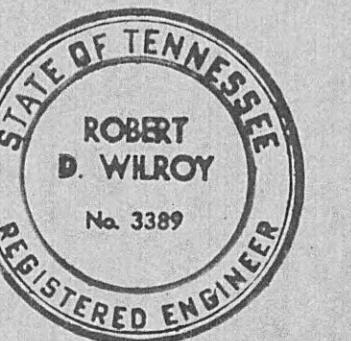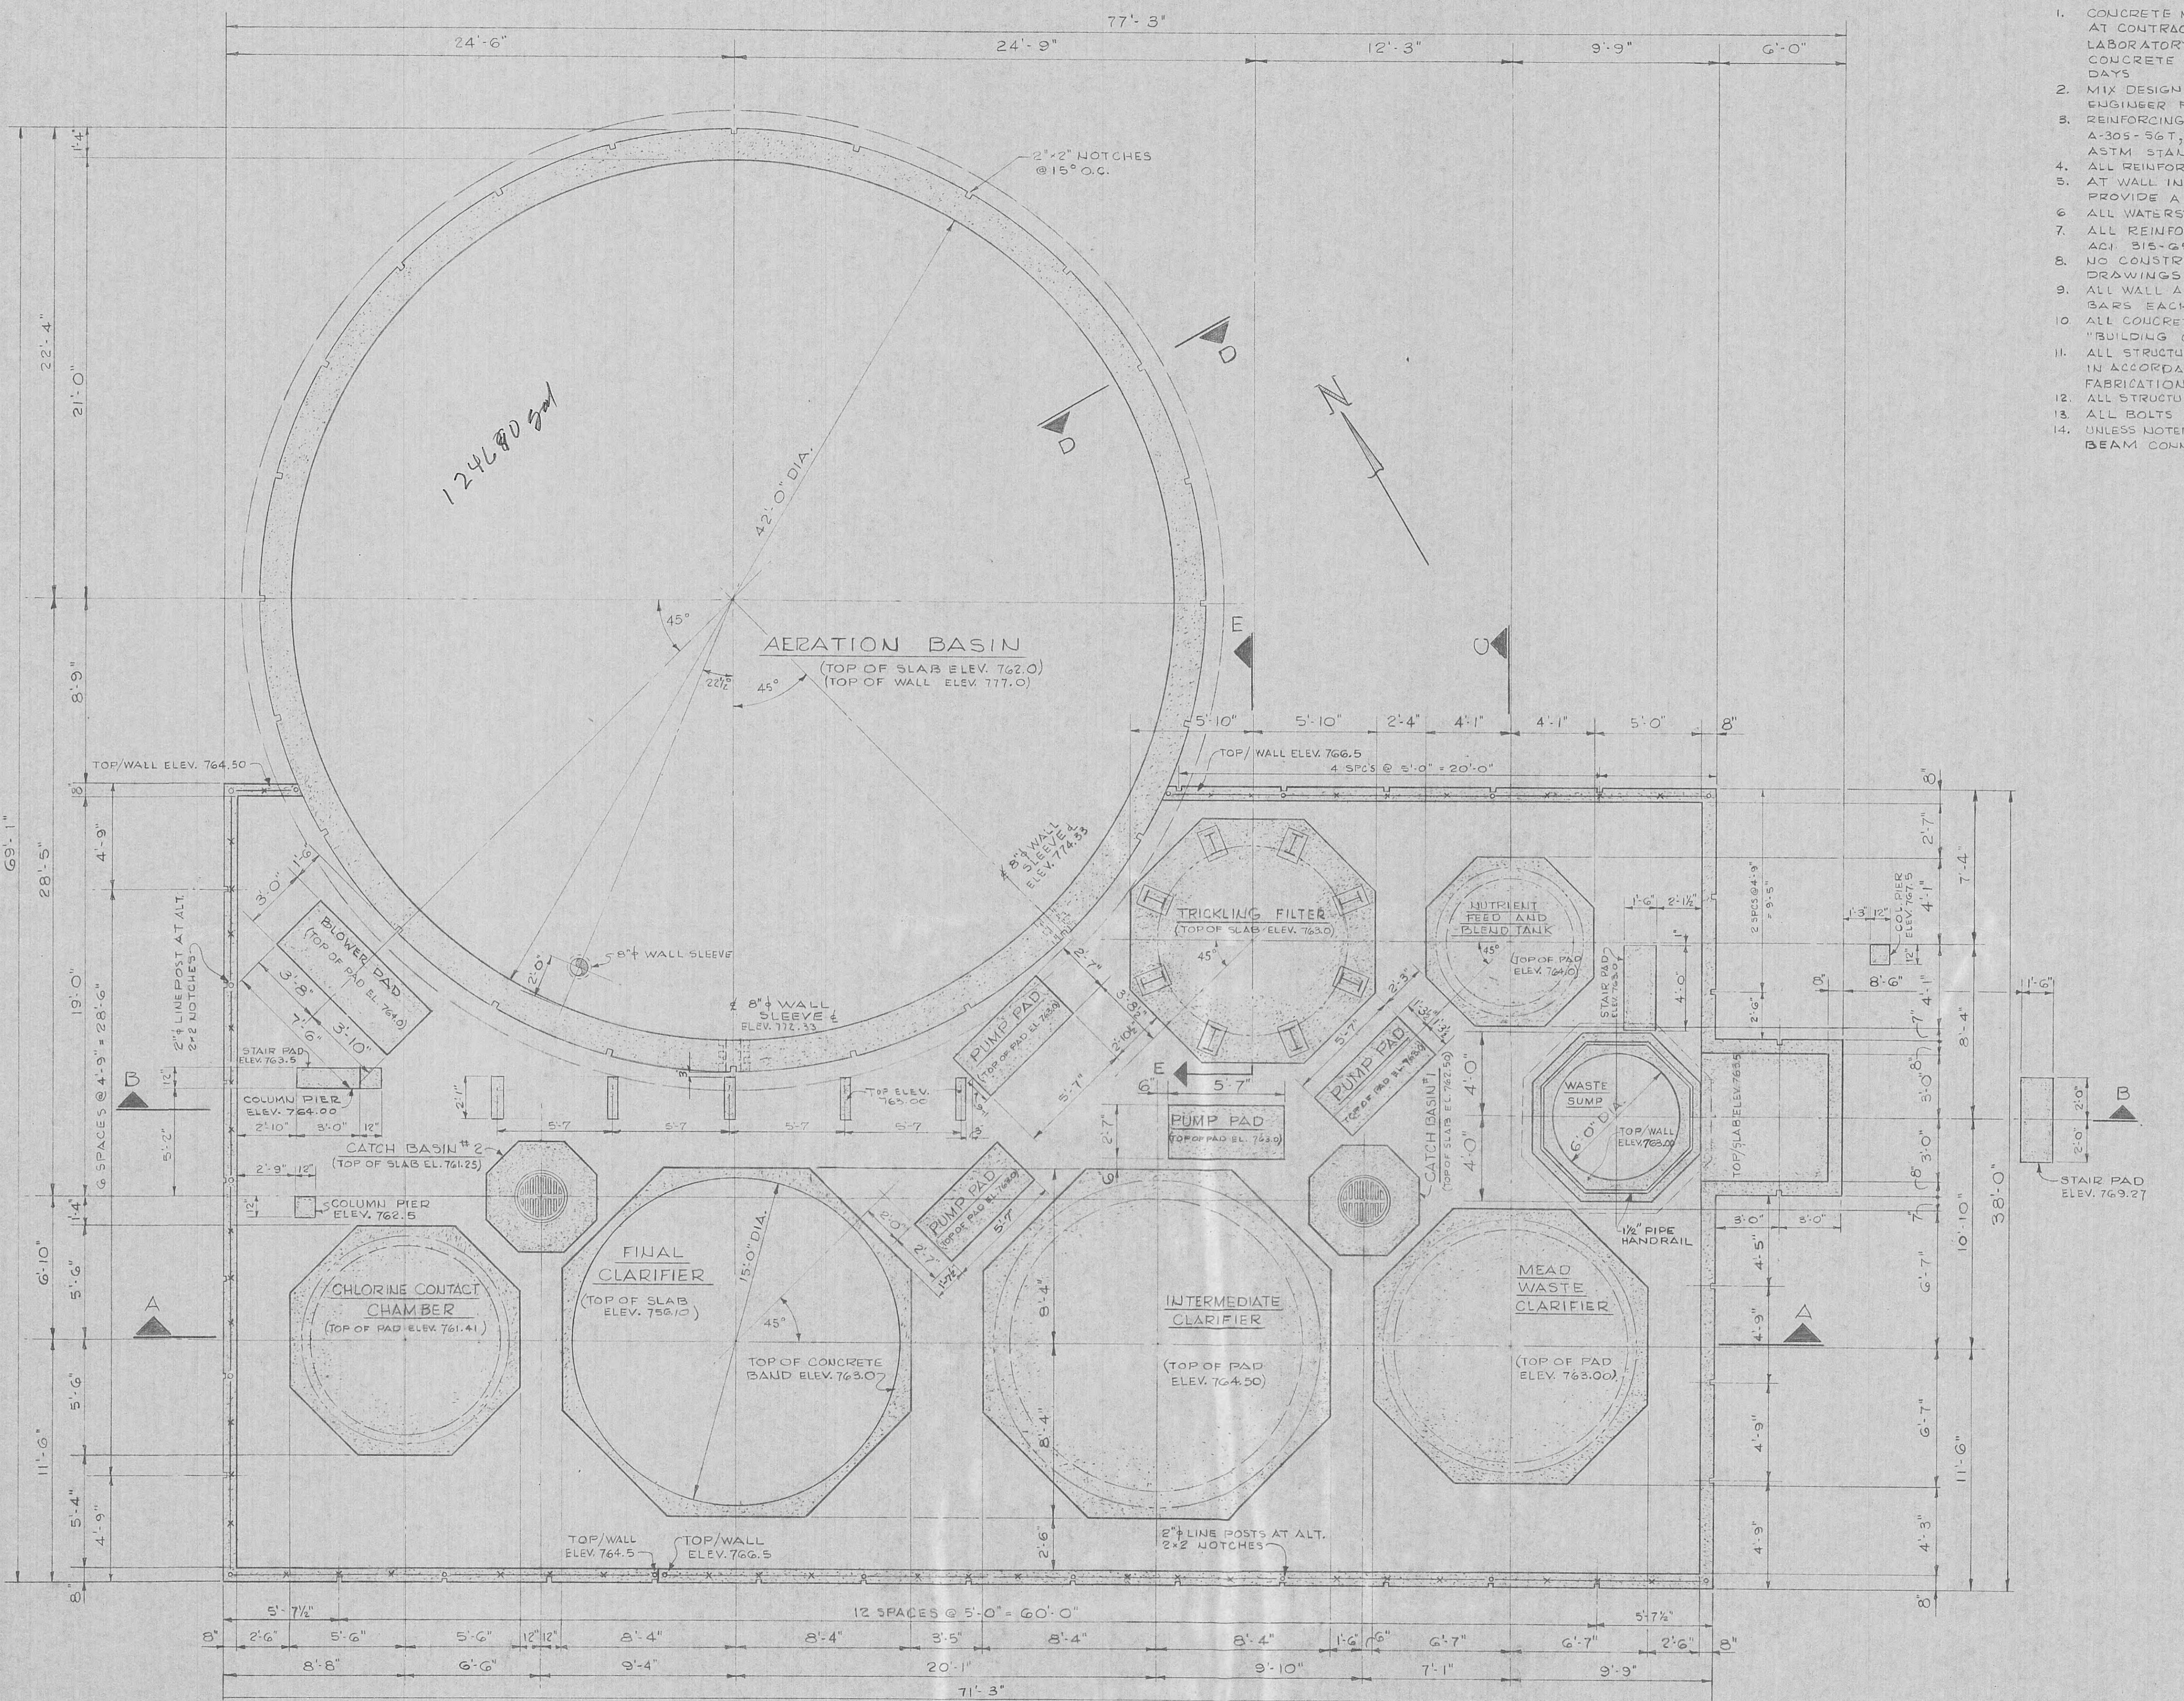

LOT WASTEWATER TREATMENT PLANT
FOR
HARRIMAN UTILITY BOARD
HARRIMAN TENNESSEE




LACK, CROW AND EIDSNESS, INC.
ALANTA INESVILLE **ENGINEERS** **GEORGIA FLORIDA**
AWN BY: WILLIAMS DATE: JUNE '69
ECKED BY: TDR FILE NO. 101-68-1

SCALE: AS SHOWN


PLATE SHEET
NO. NO.


SUBSIDIZATION PLAN **S-1** **S**
OF 6 **OF 26**

Digitized by srujanika@gmail.com

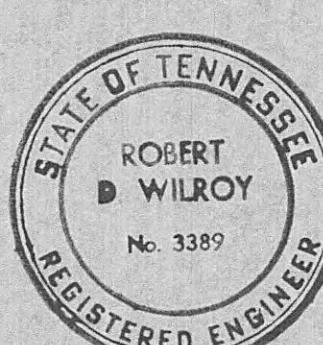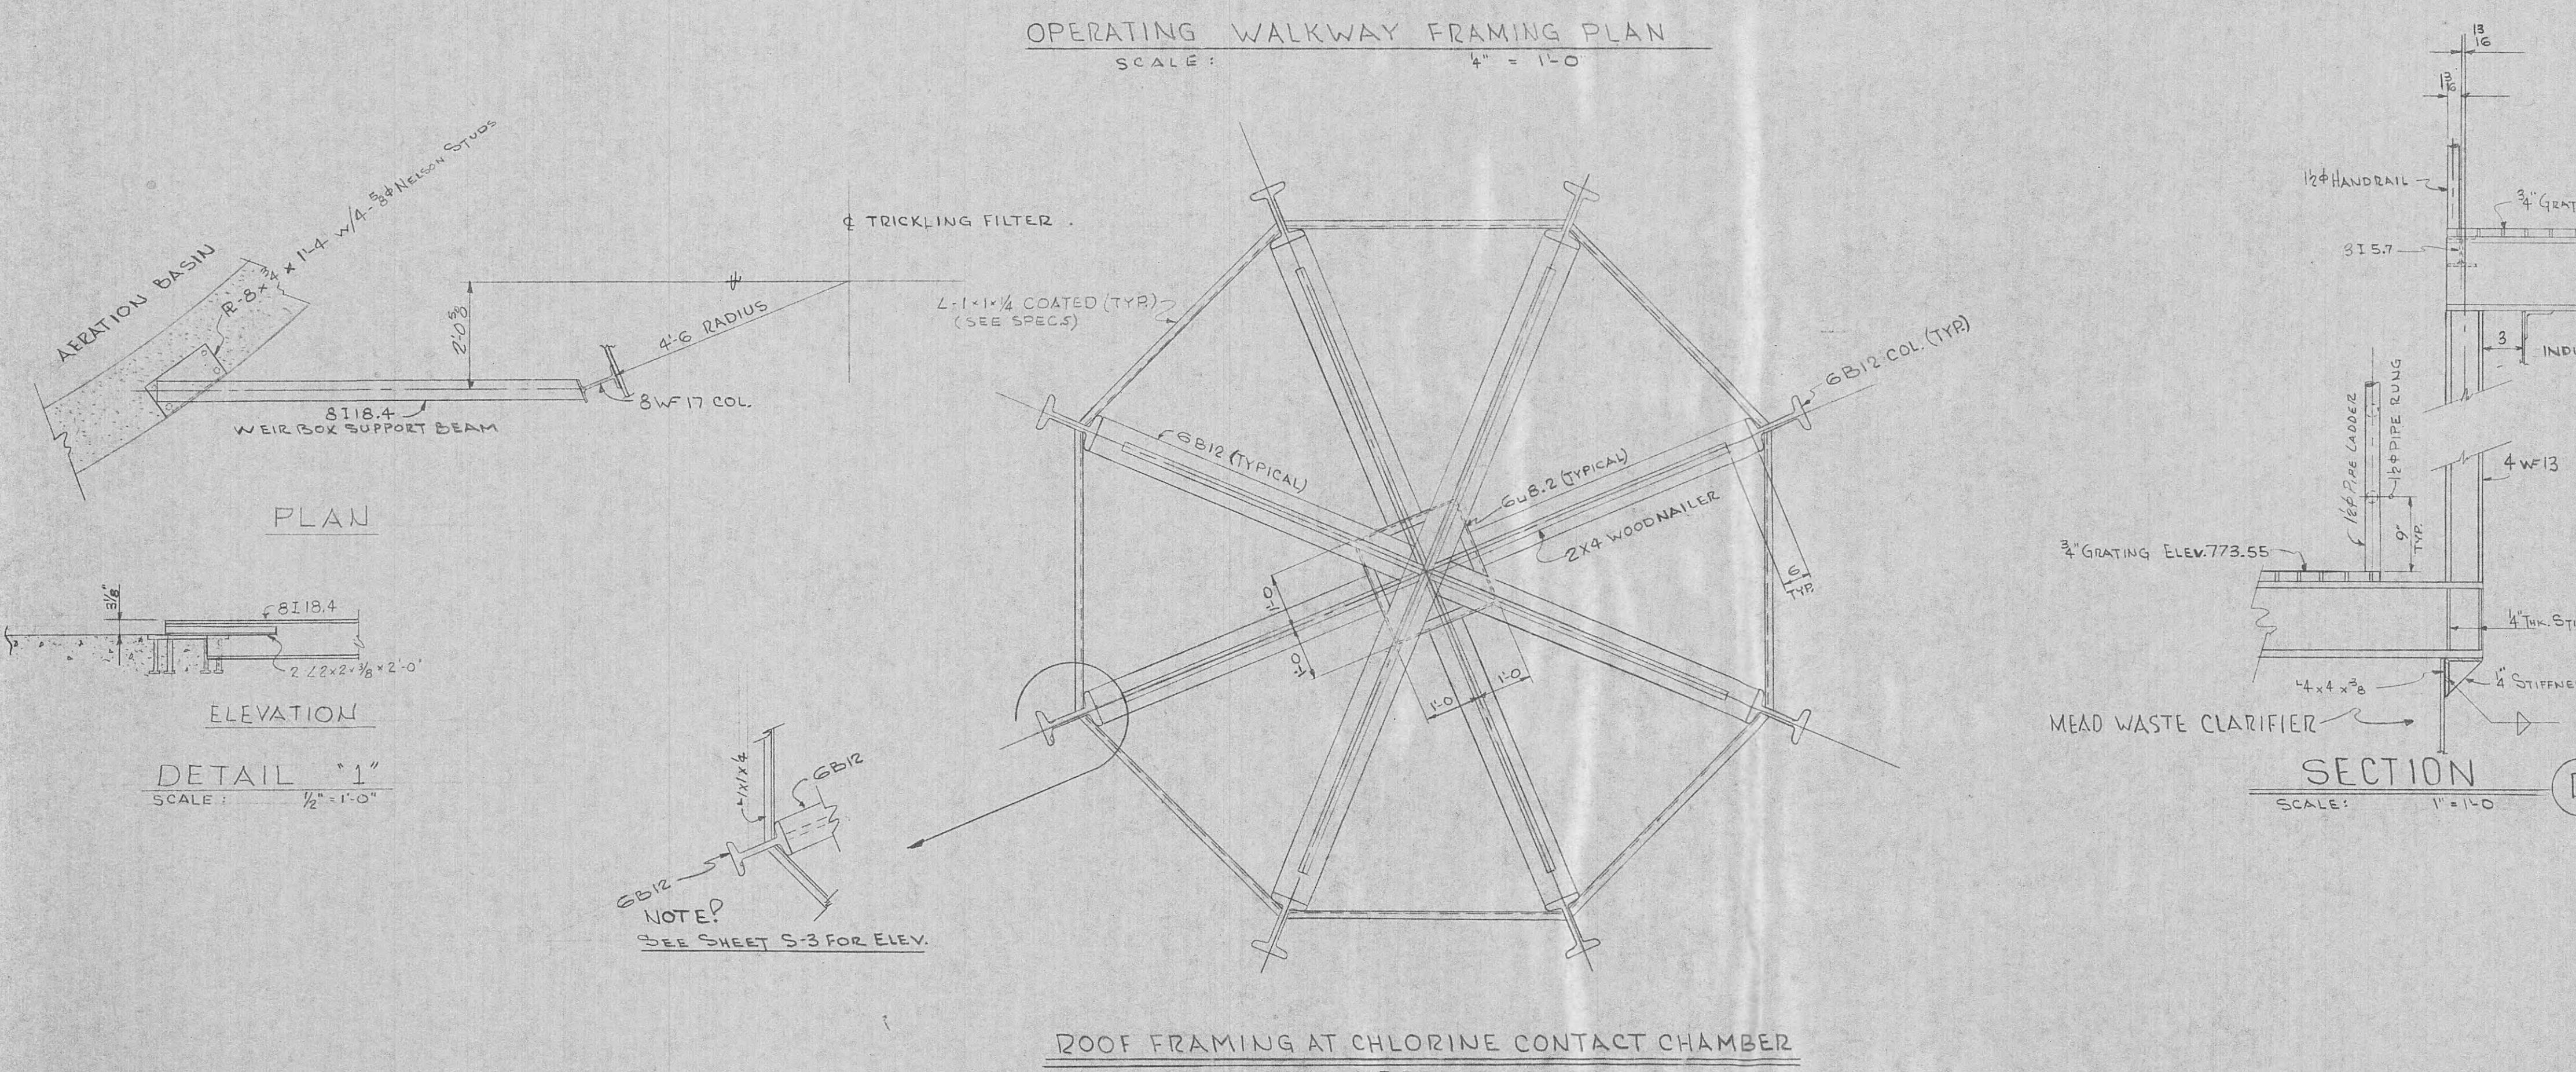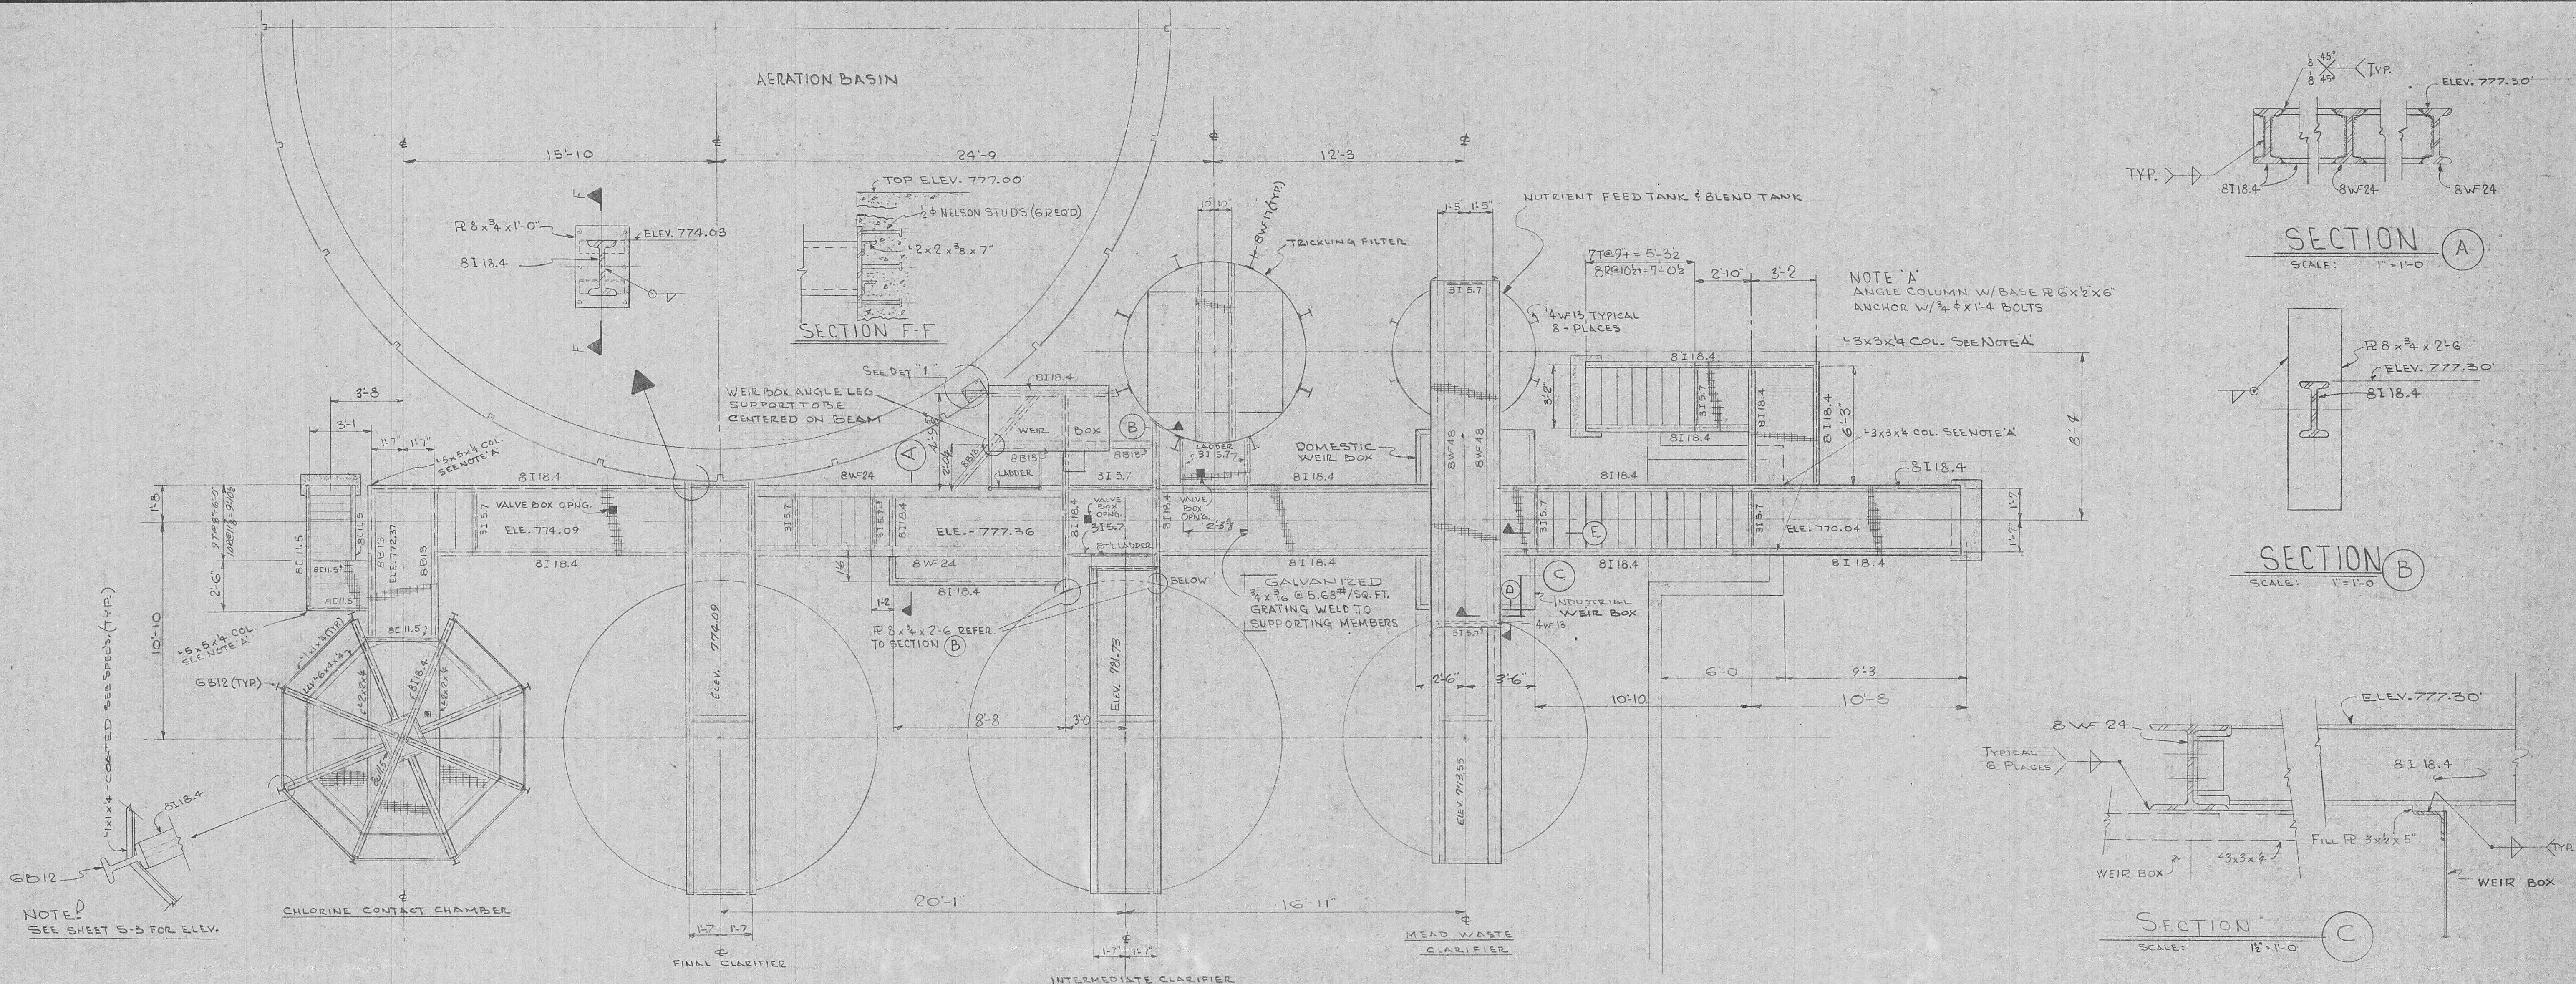


| | | | |
|---|--------------------|---------------------|----------------------------|
| LOT WASTEWATER TREATMENT PLANT FOR HARRIMAN UTILITY BOARD | | | |
| HARRIMAN | TENNESSEE | | |
| BLACK, CROW AND EIDSNESS, INC. | | | |
| ATLANTA AINESVILLE | ENGINEERS | | |
| | GEORGIA FLORIDA | | |
| DRAWN BY: WILLIAMS | DATE: JUNE '69 | | |
| CHECKED BY: T.D.R. | FILE NO. 484-69-1 | | |
| SCALE: AS SHOWN | | | |
| ERATING PLATFORM OUT & DETAILS | | PLATE NO. S-2 | SHEET NO. 6 OF 26 |



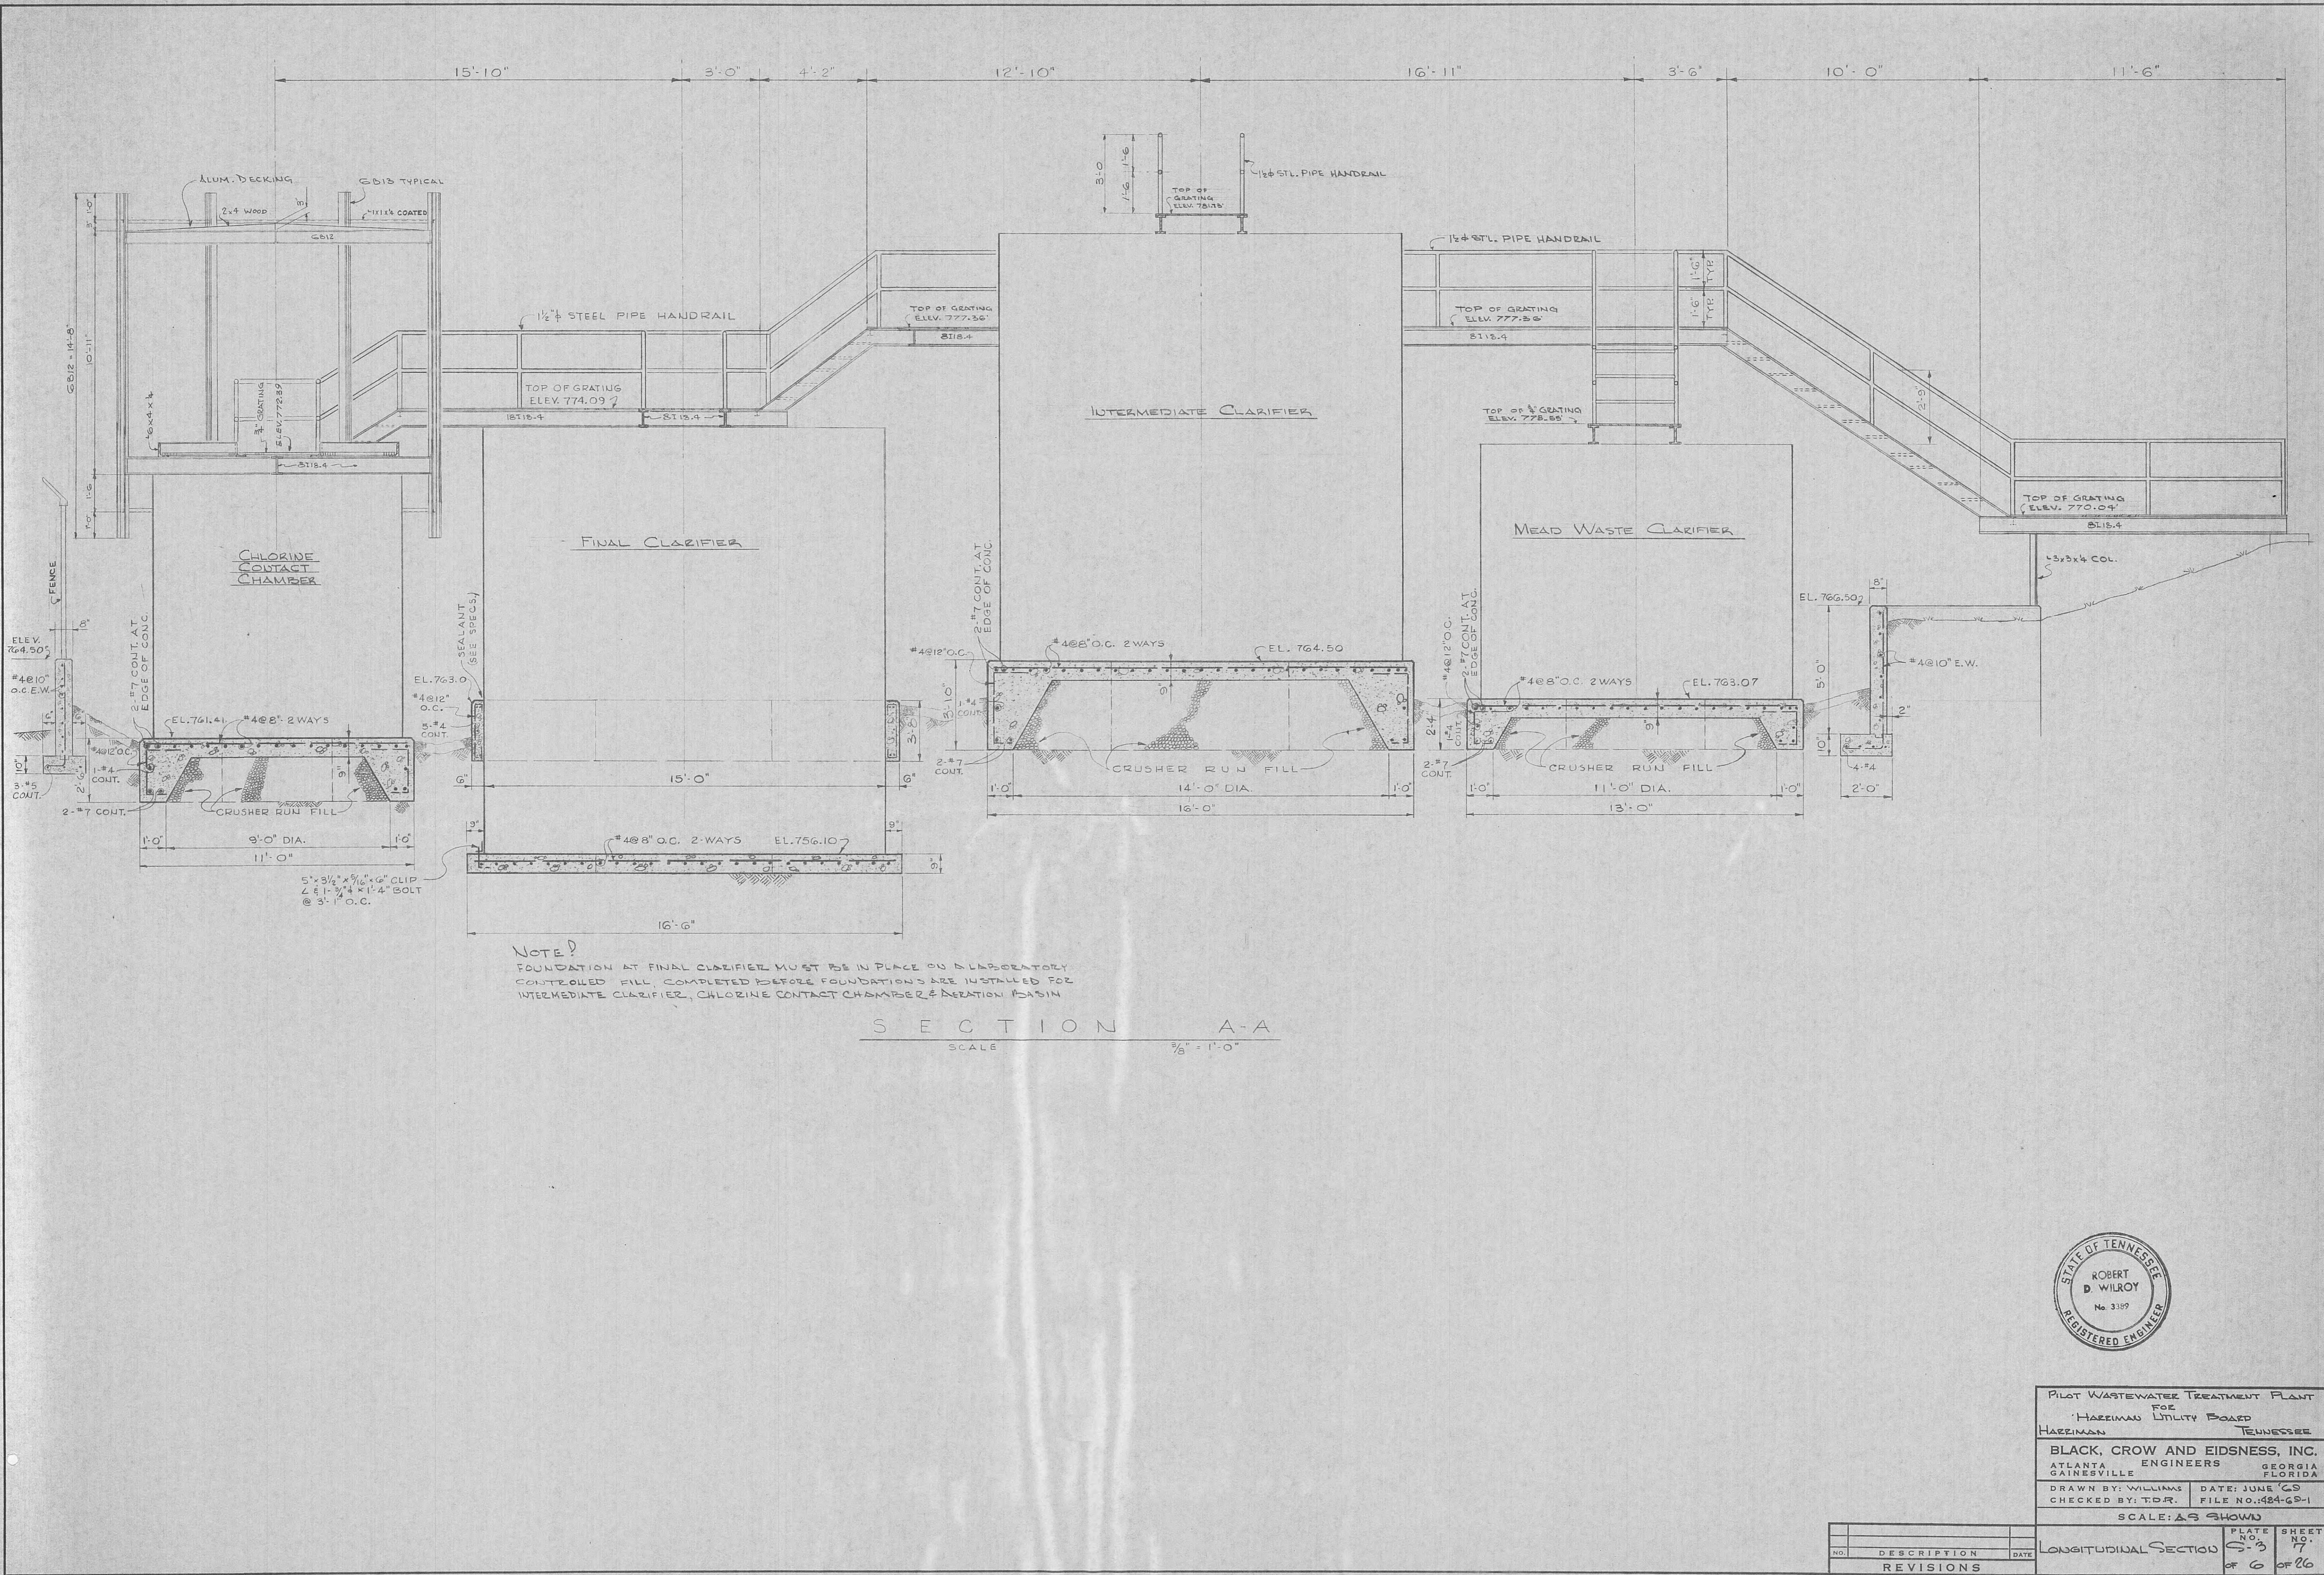


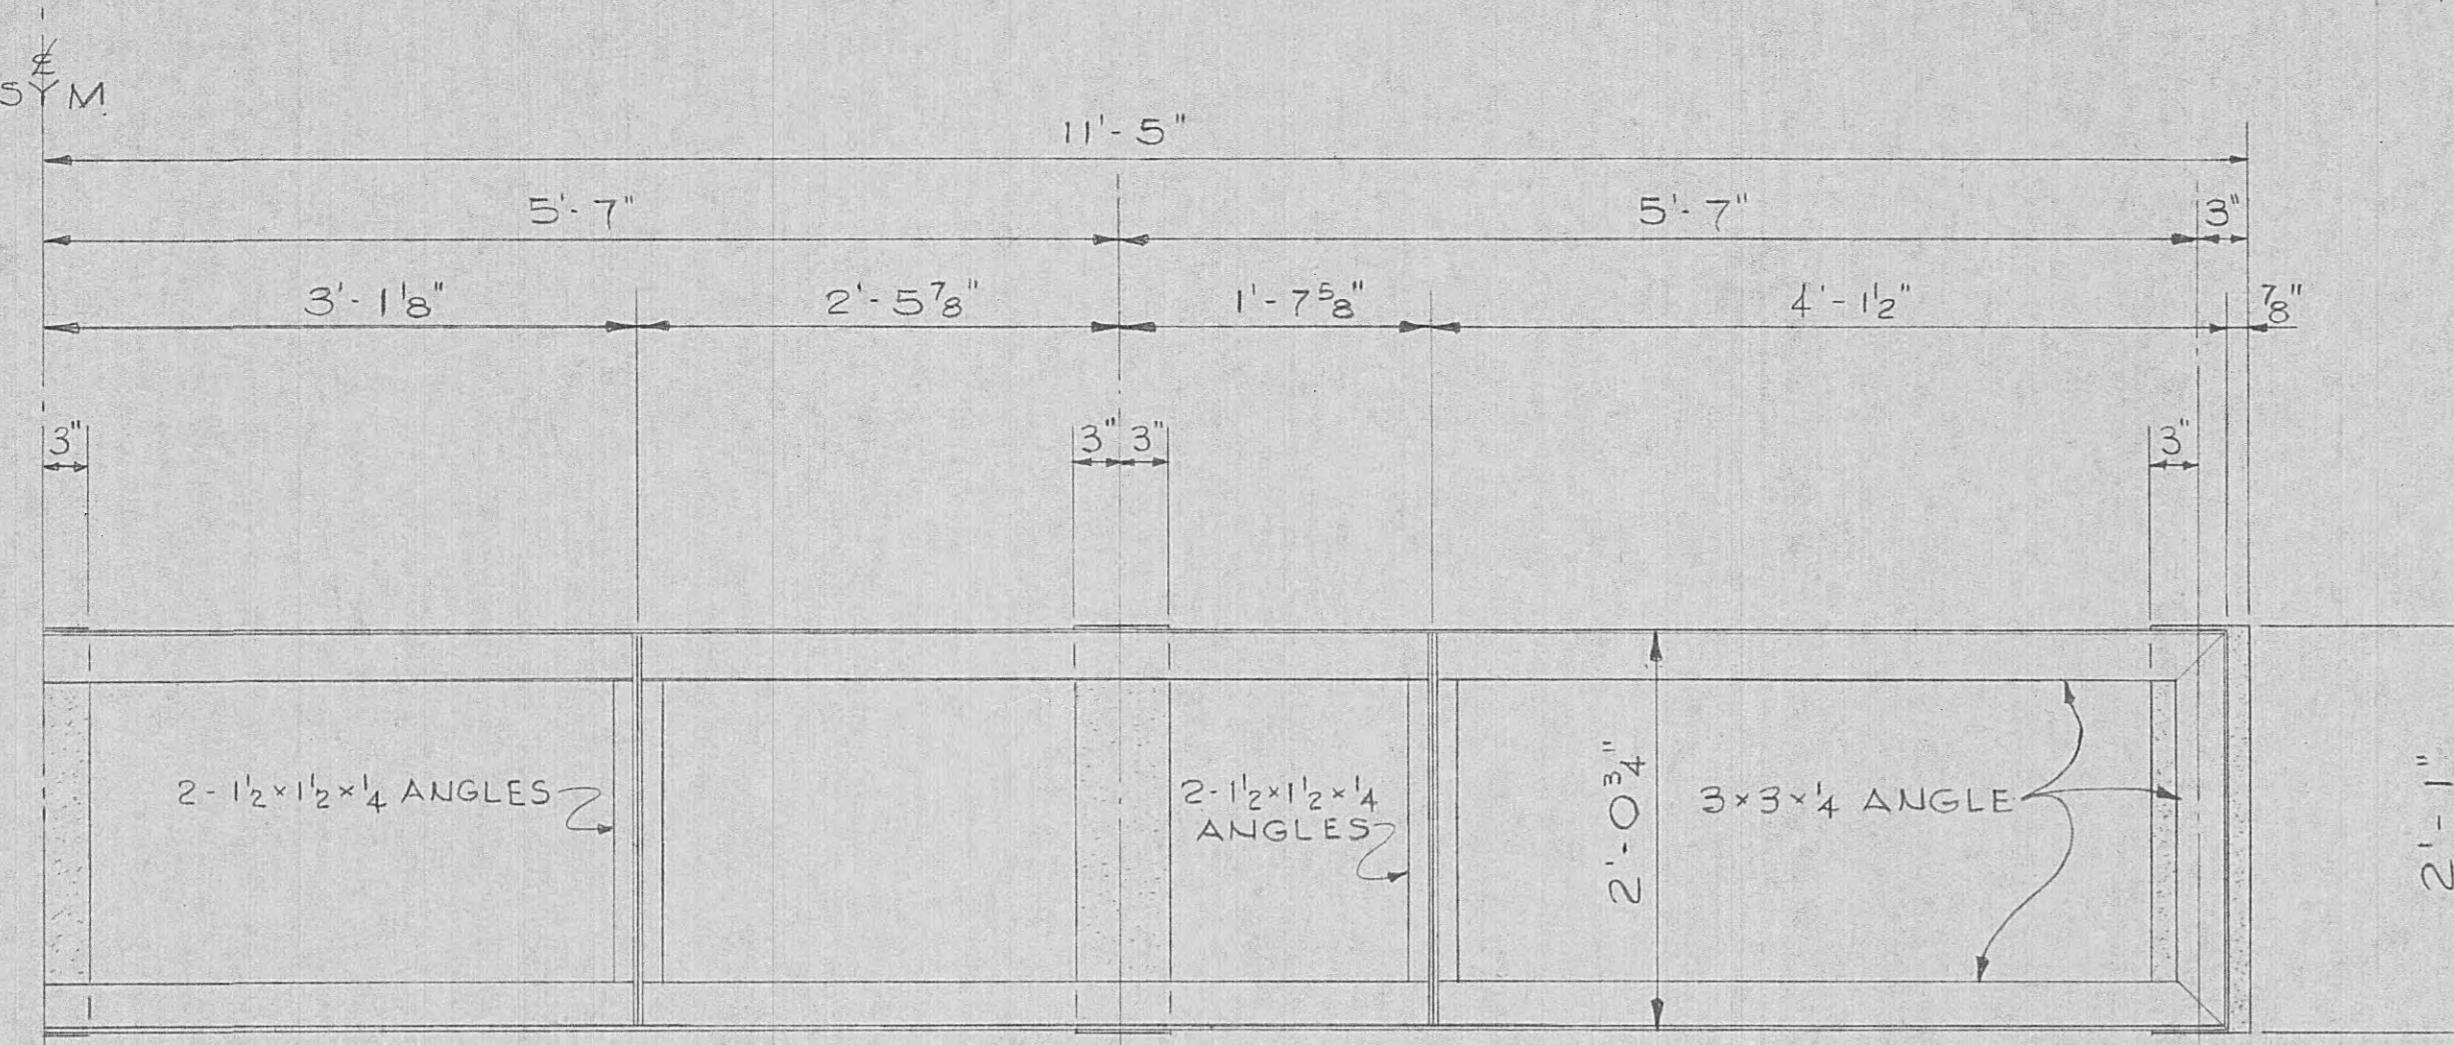

PLAN OF DRUM RACK


SCALE : 1" = 1'-0"

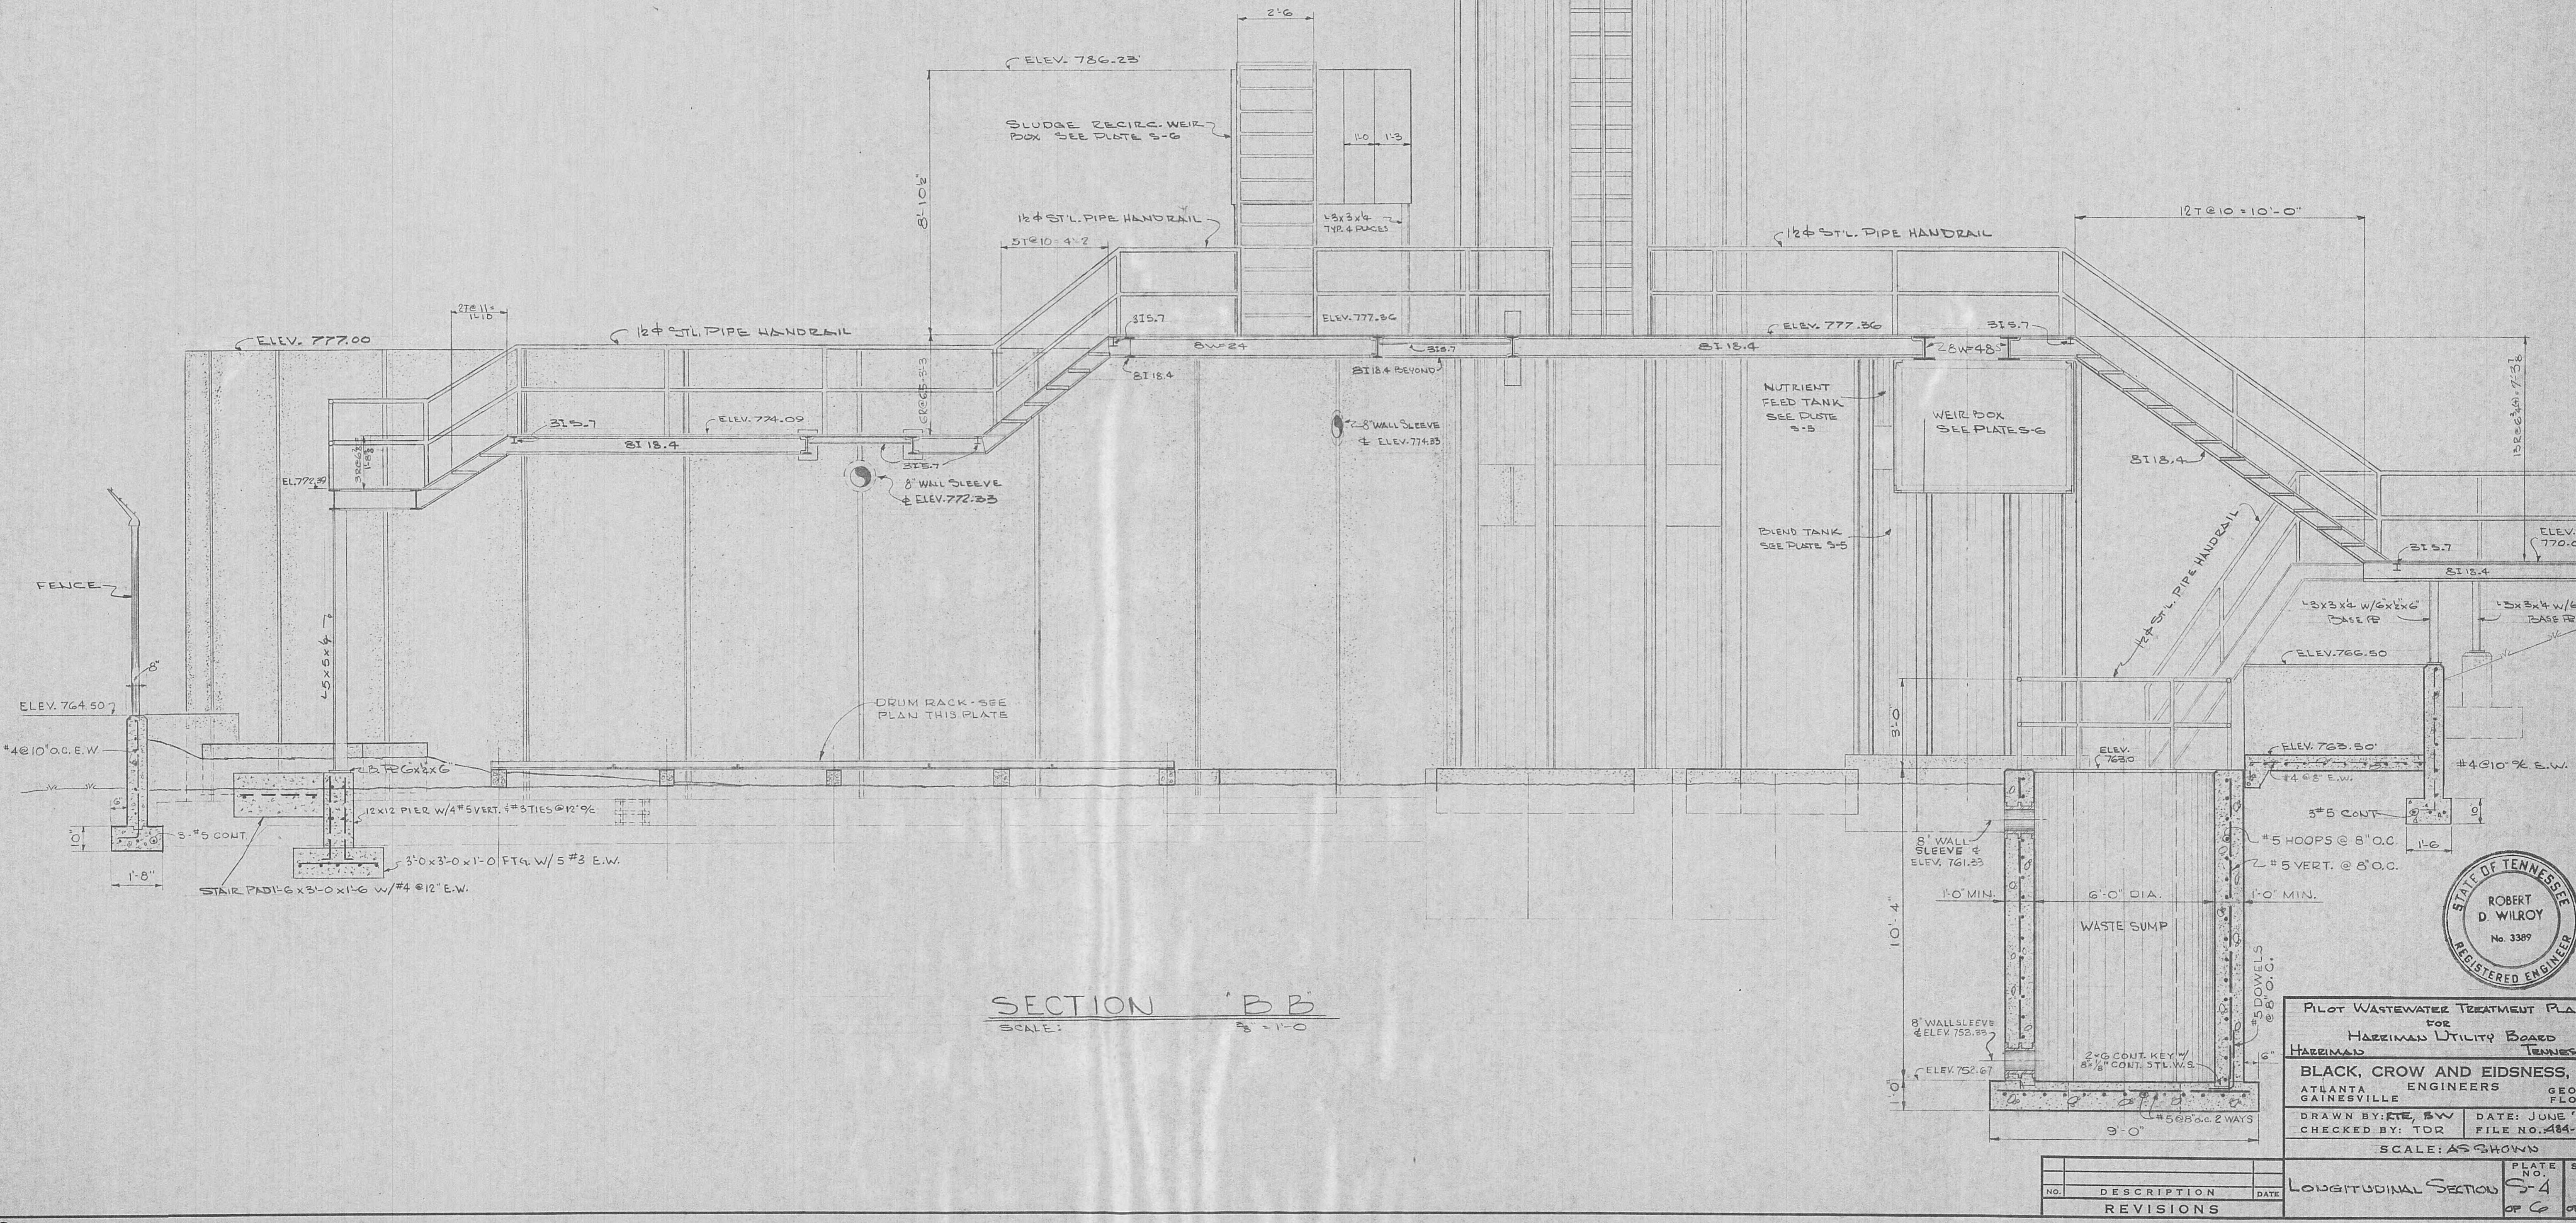

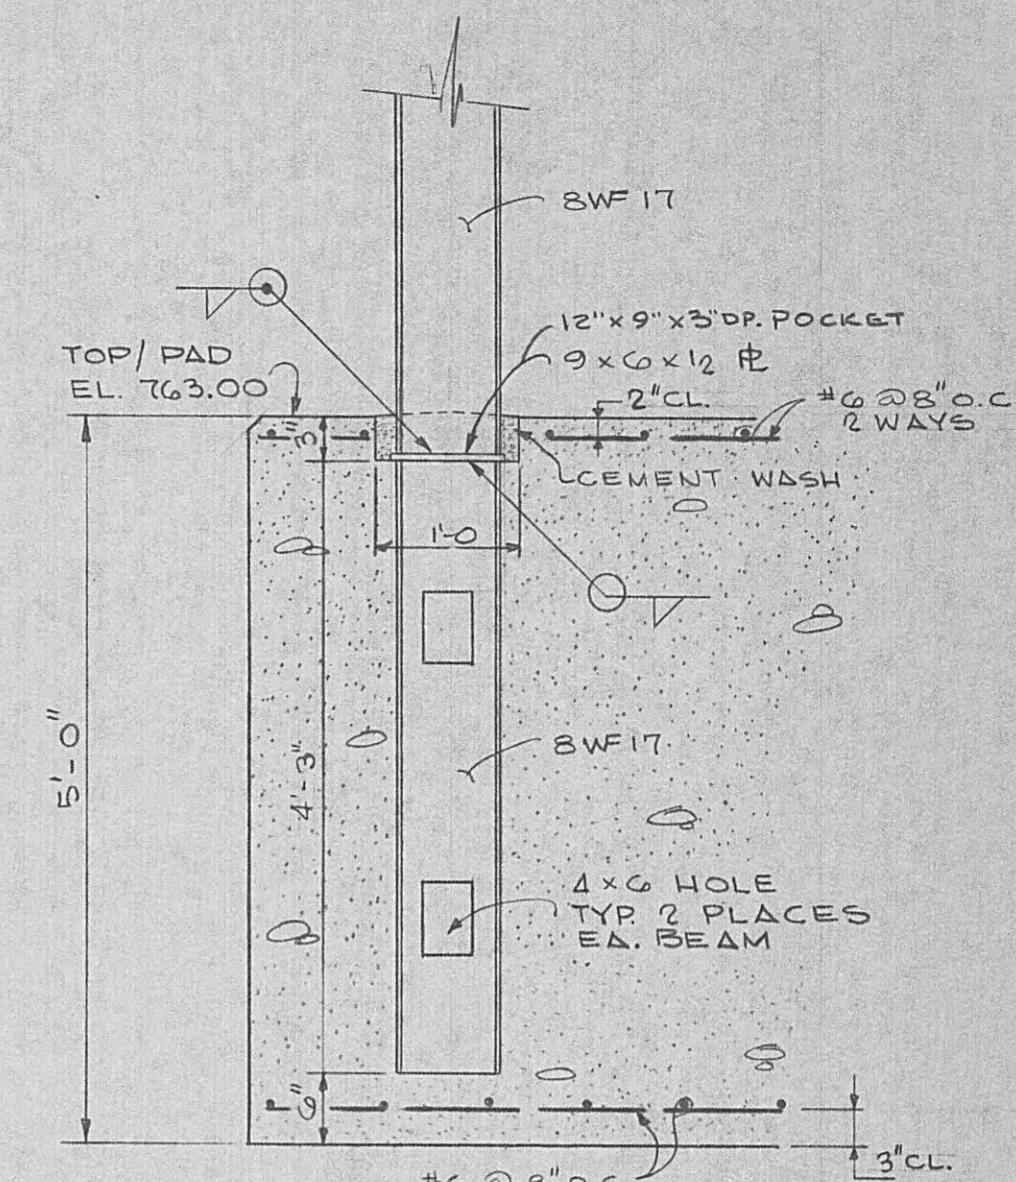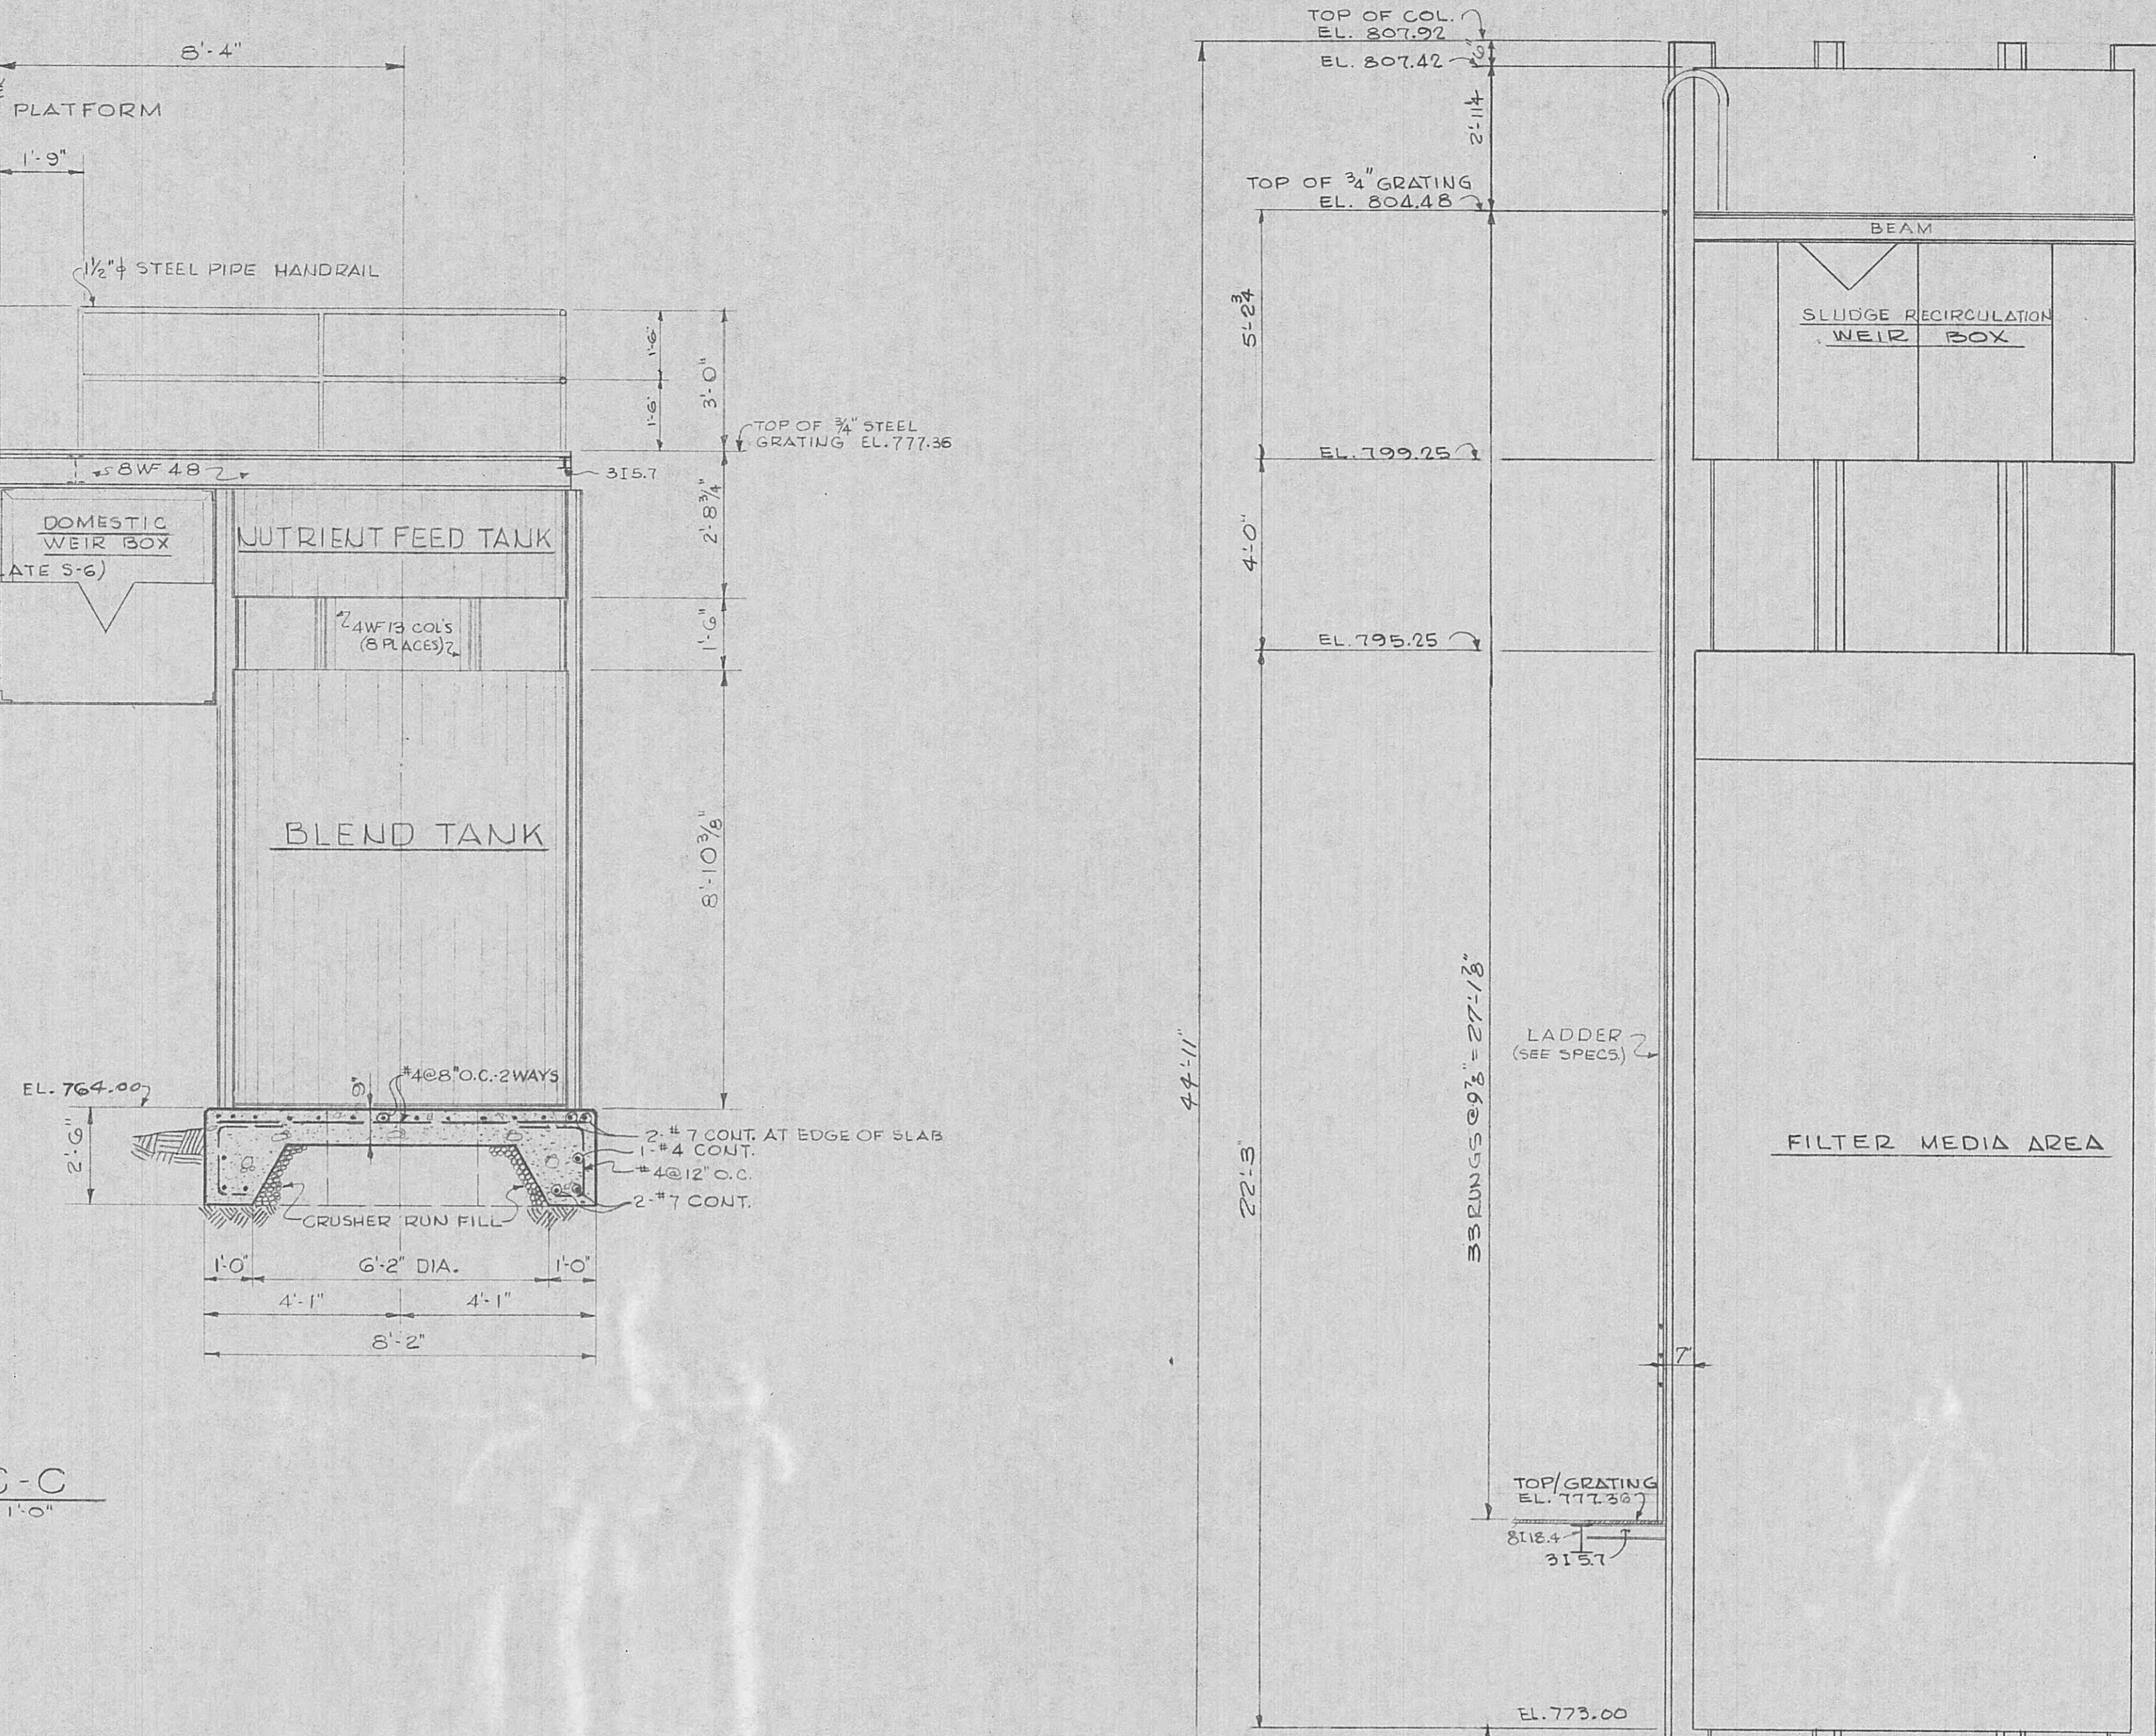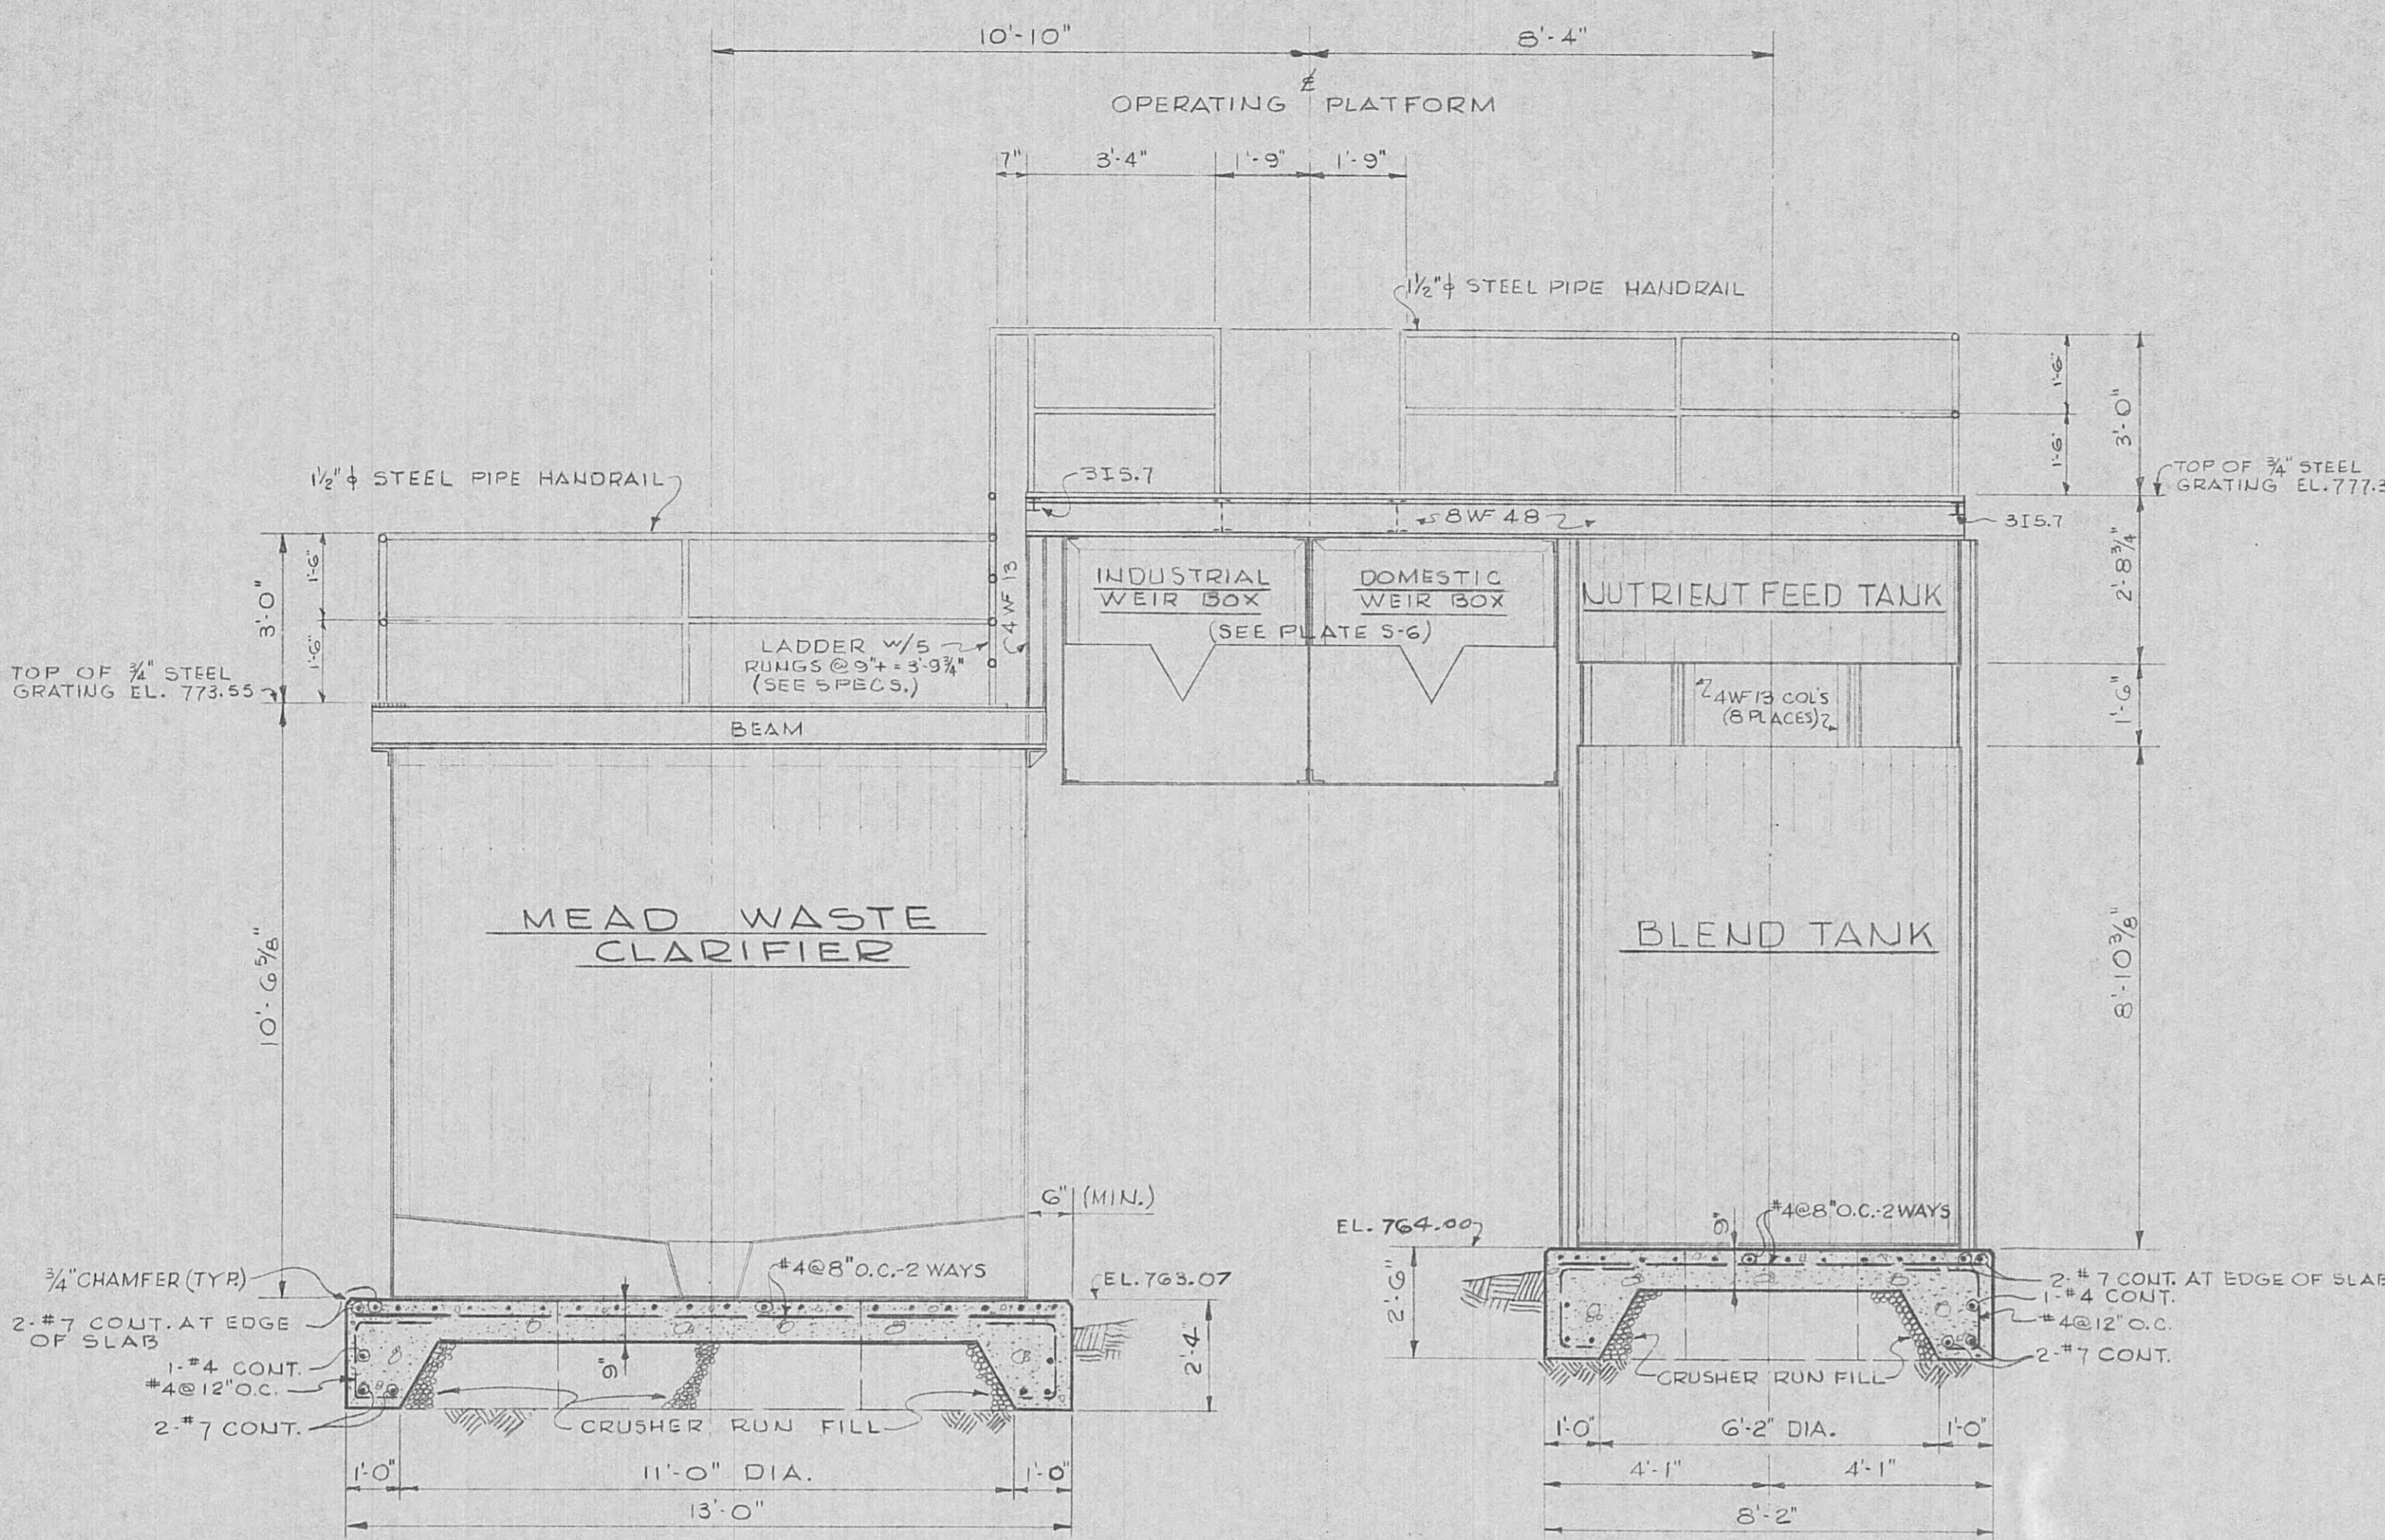

DETAIL
SCALE: $\frac{3}{4}'' = 1'-0''$

SECTION C-C
SCALE: $\frac{3}{8}'' = 1'-0''$

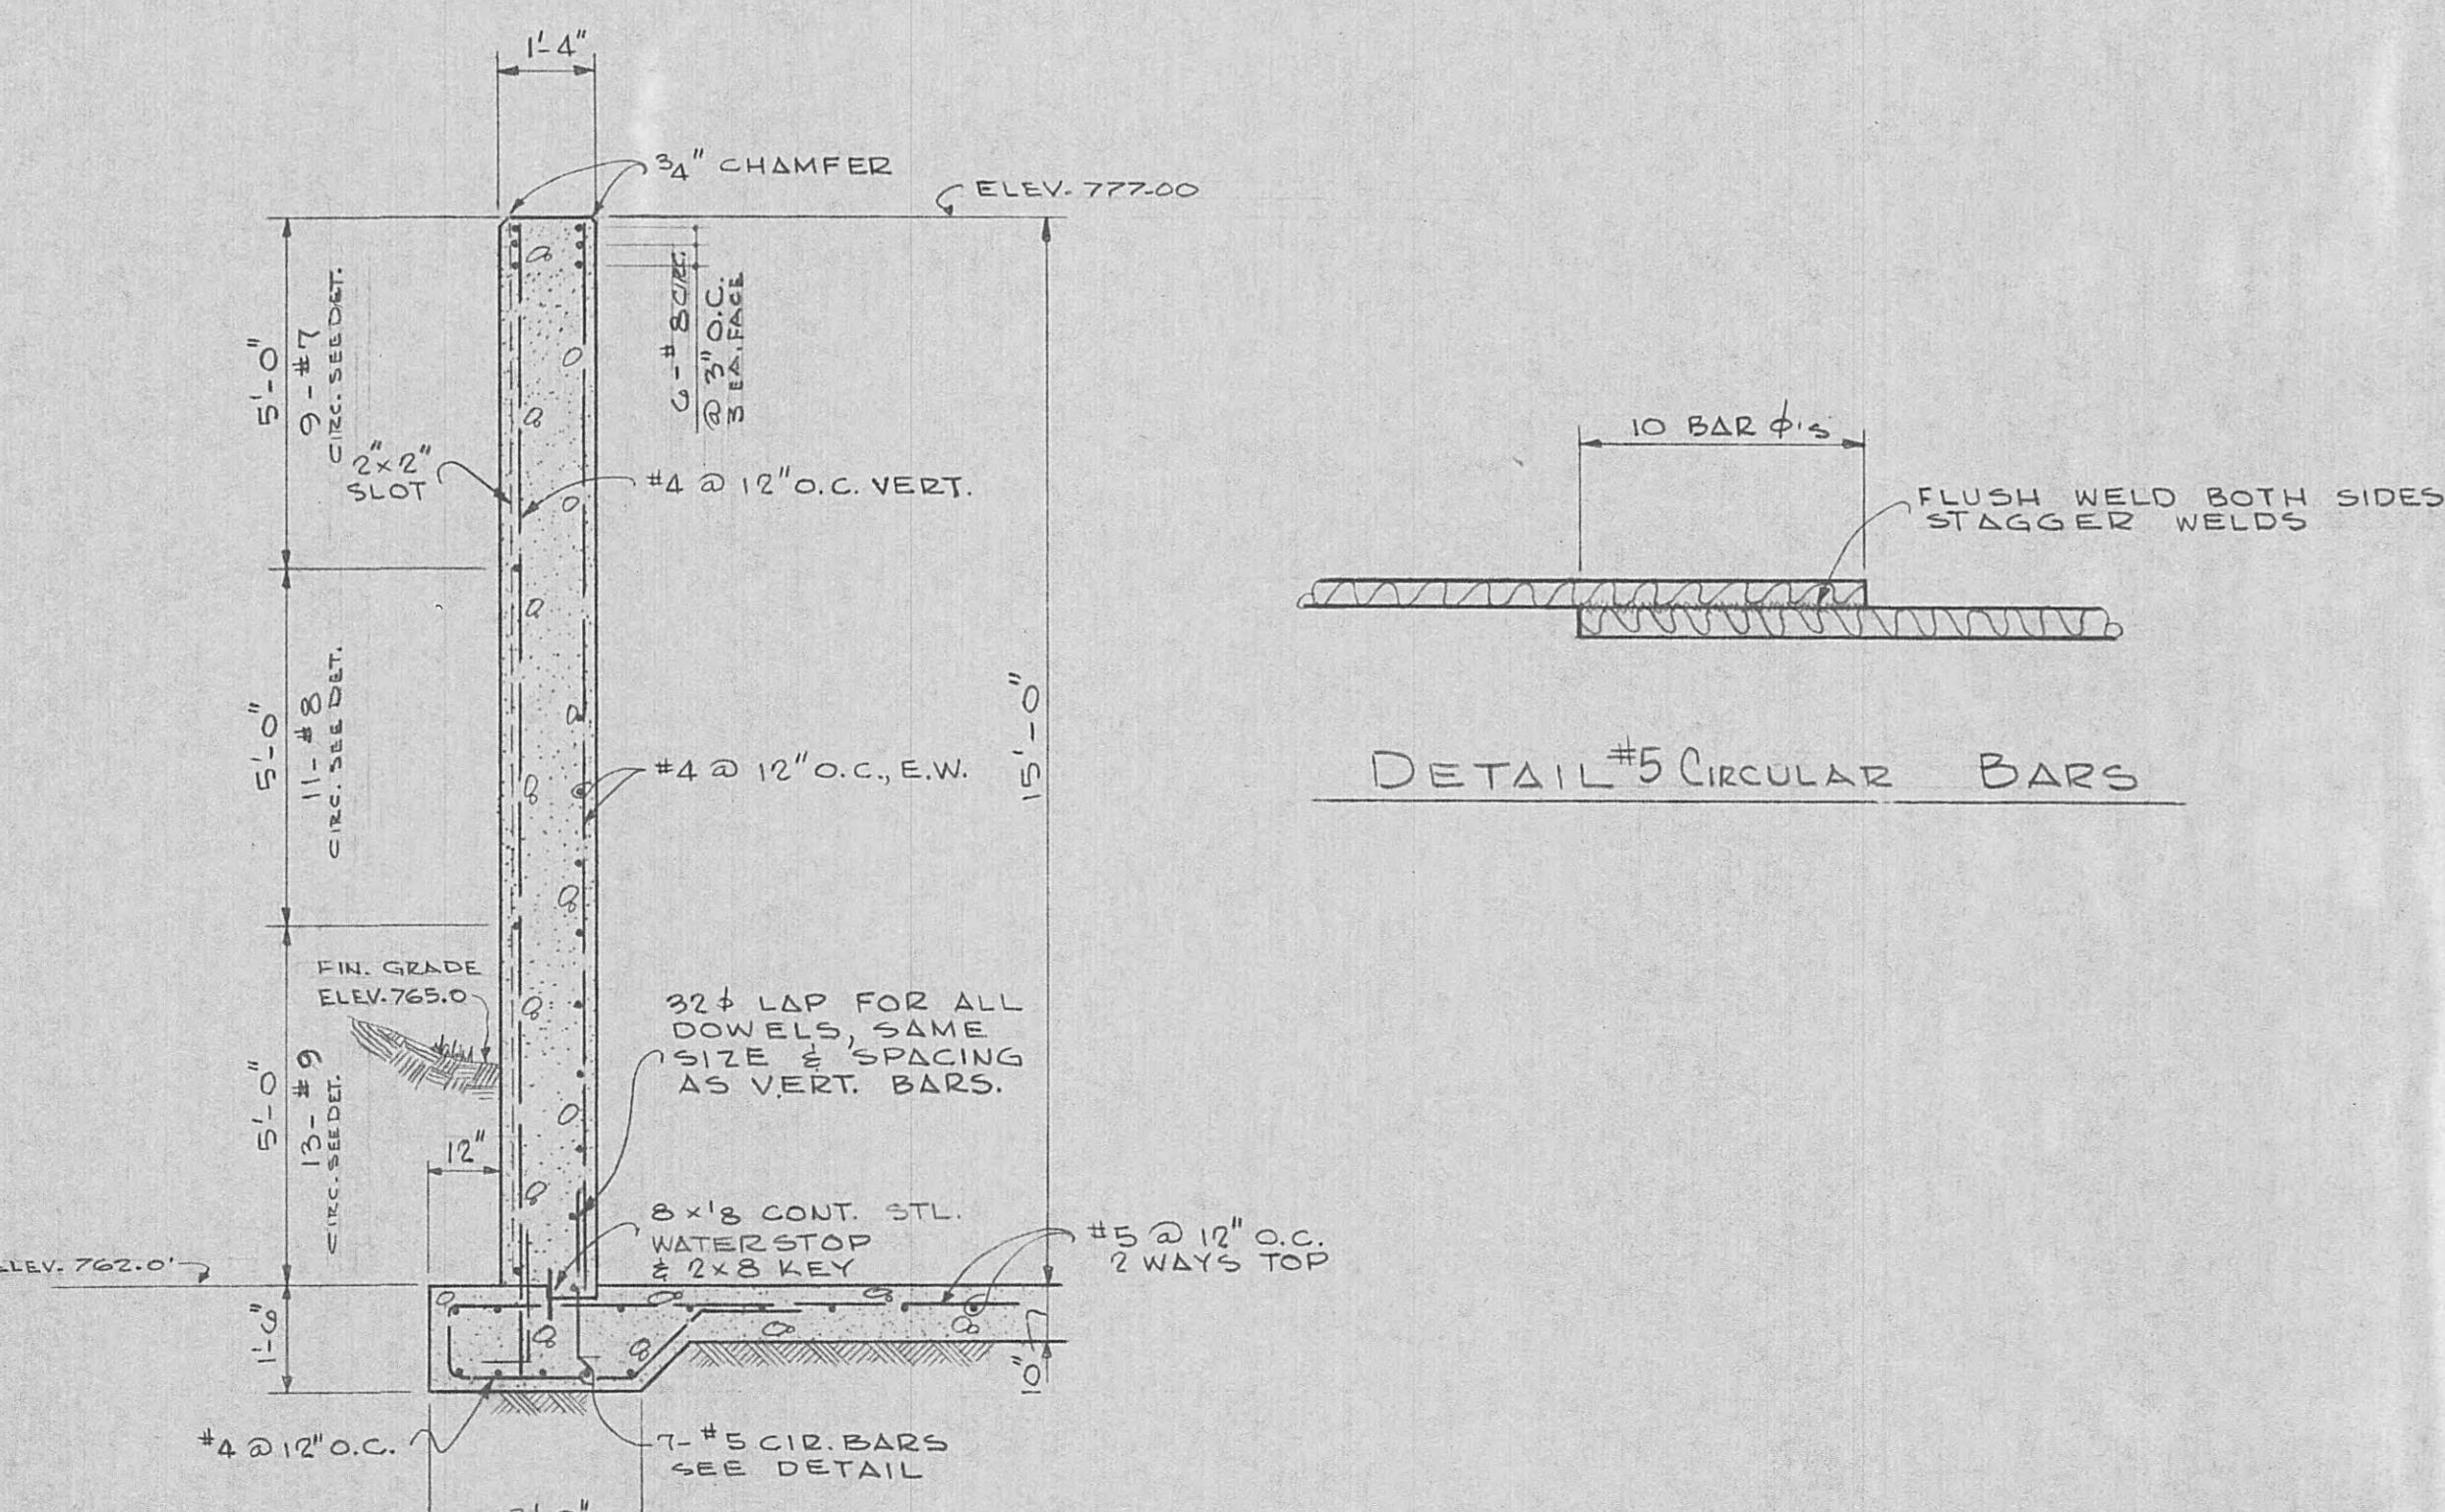

DETAIL #5 CIRCULAR BARS

SECTION D-D
SCALE: $\frac{3}{8}'' = 1'-0''$

SECTION E-E
SCALE: $\frac{3}{8}'' = 1'-0''$

Pilot Wastewater Treatment Plant
for Harriman Utility Board
Harriman Tennessee
Black, Crow and Eidsness, Inc.
Atlanta, Georgia
Engineers
Gainesville, Florida
Drawn By: RM.BW Date: June '99
Checked By: TDR File No. 484-24-1
Scale: As Shown

| NO. | DESCRIPTION | DATE |
|---------------------|--------------------|-------------------|
| TRANSVERSE Sections | PLATE NO. 5-5 OF 6 | SHEET NO. 9 OF 26 |

STATE OF TENNESSEE
ROBERT
D. WILROY
No. 3309
REGISTERED ENGINEER