


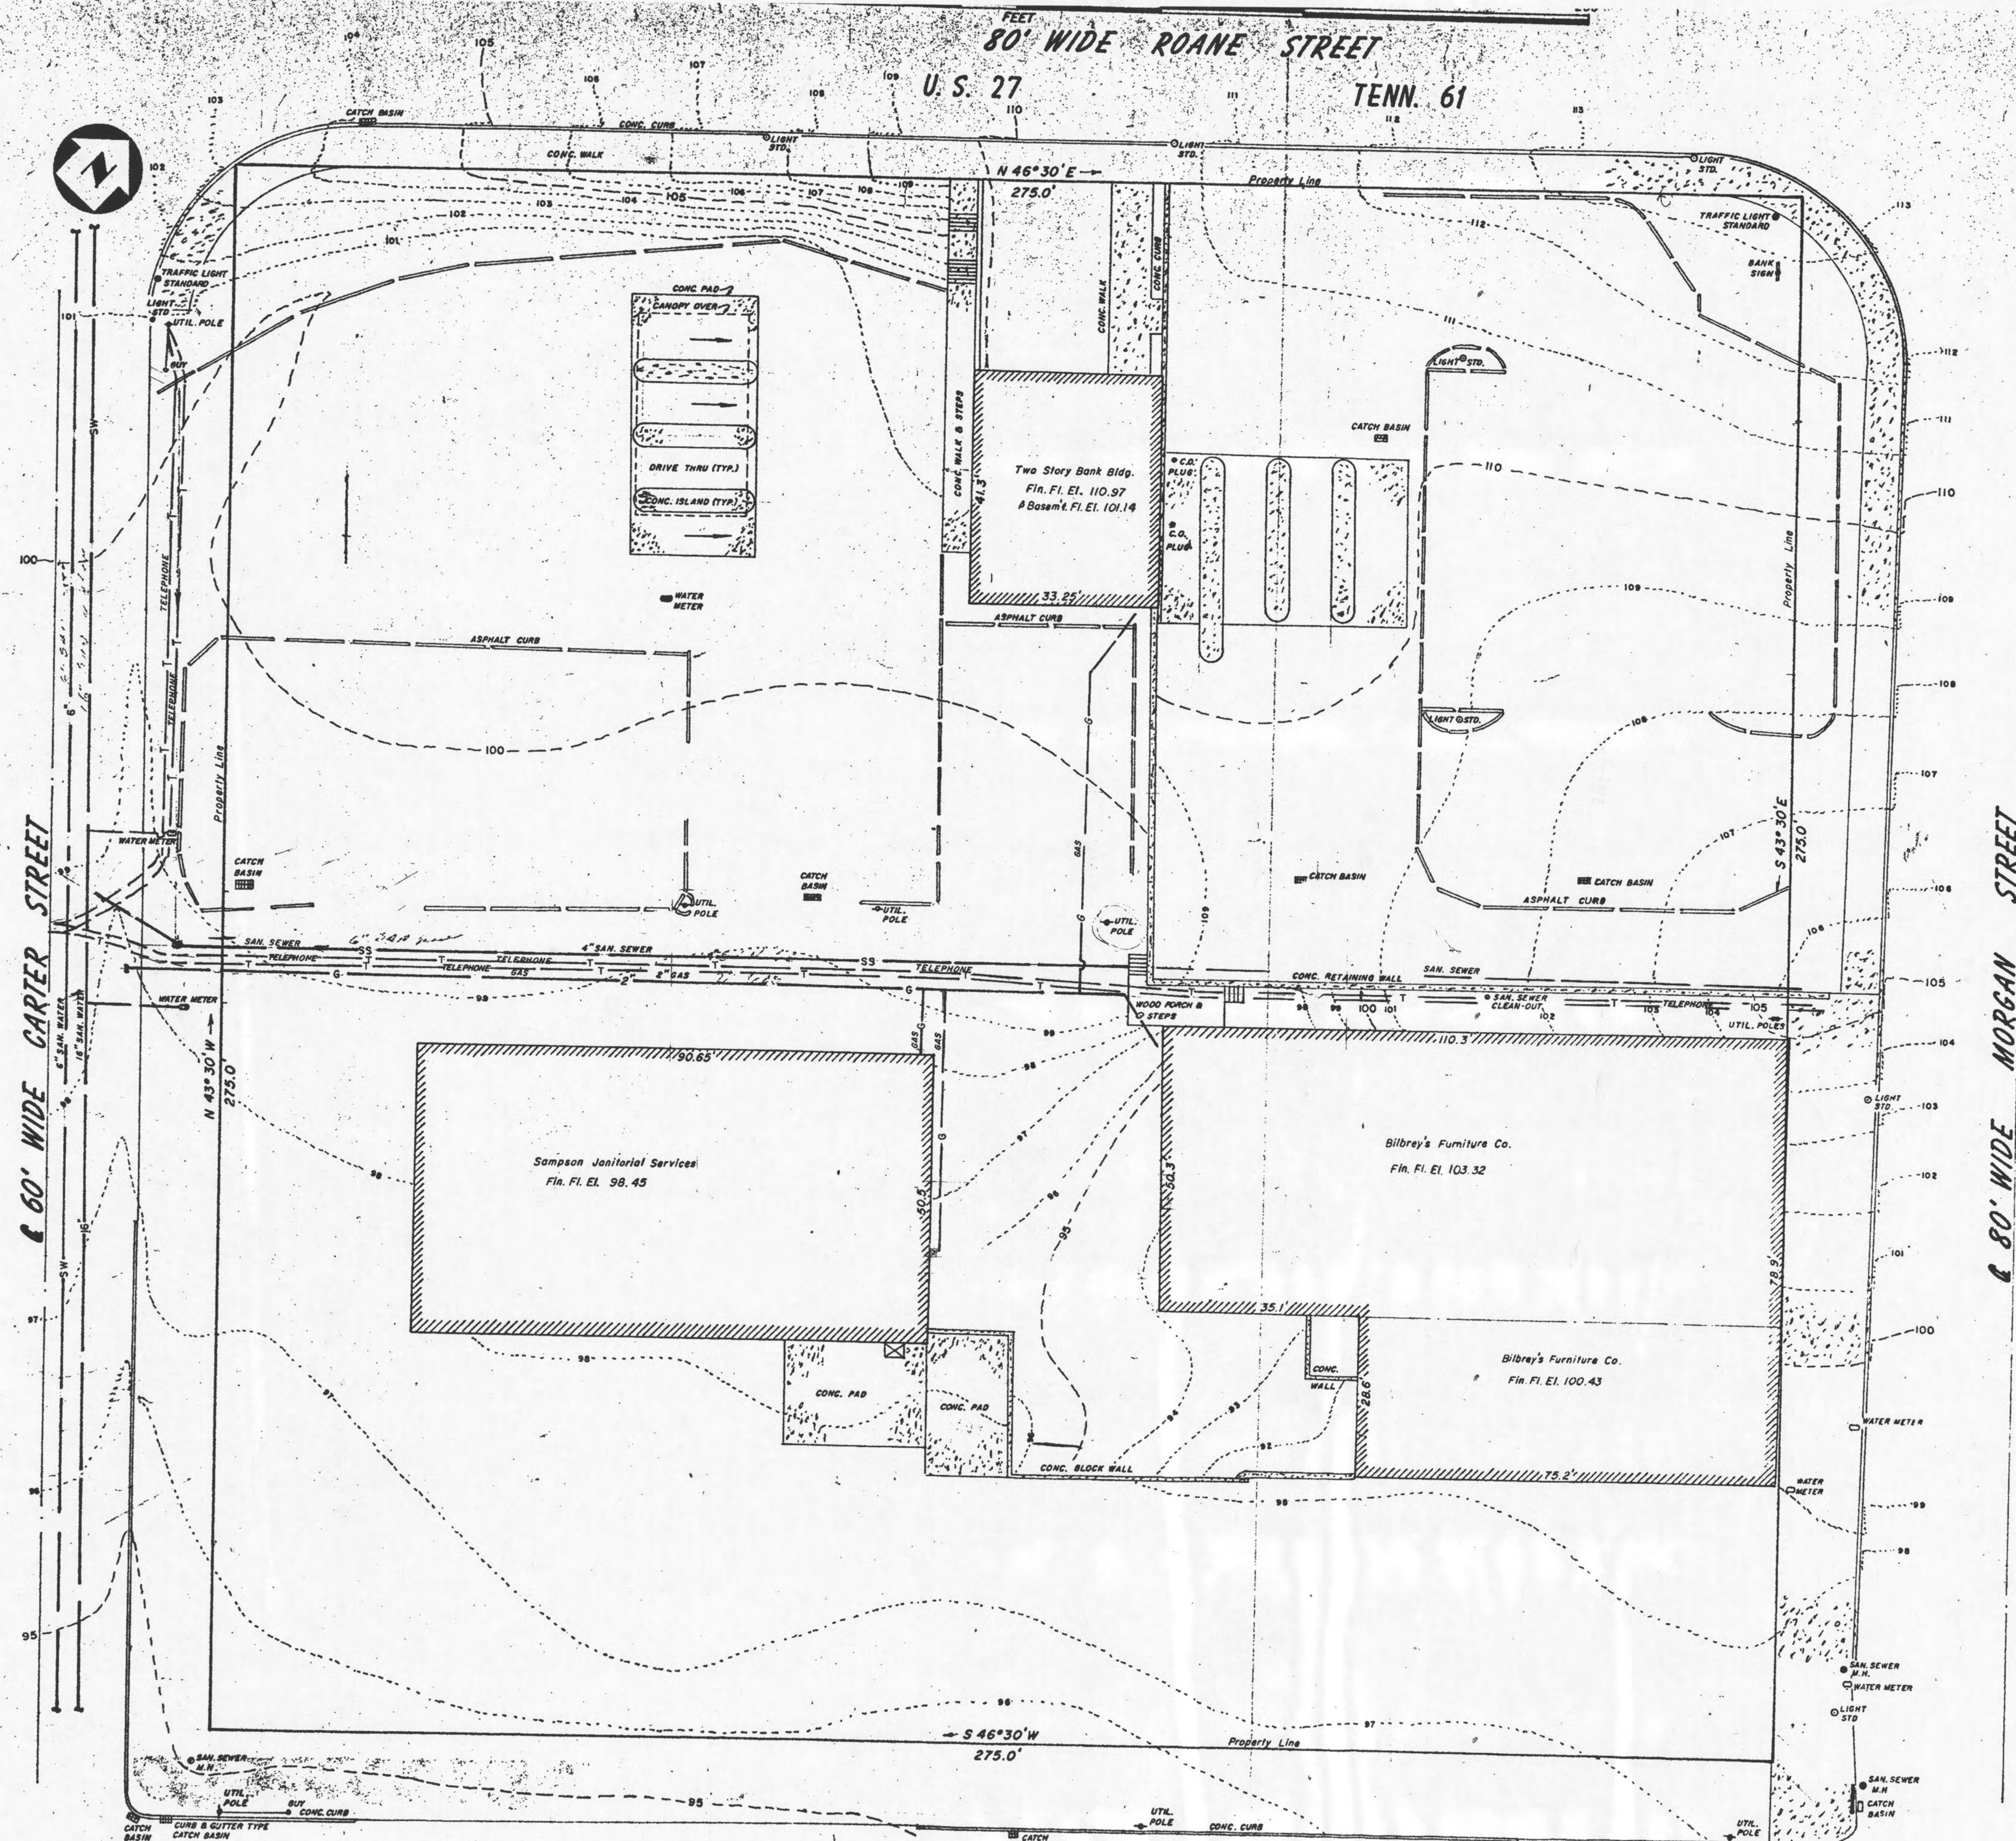



NOTE:
 Exact Size, Location, and Elevation of
 existing utilities are unknown.
 Elevations shown are assumed and not
 above sea level datum.

60' WIDE TRENTON STREET

PLAN
 SCALE: 1/16" = 1'-0"


BANK OF ROANE COUNTY HARRIMAN, TENNESSEE

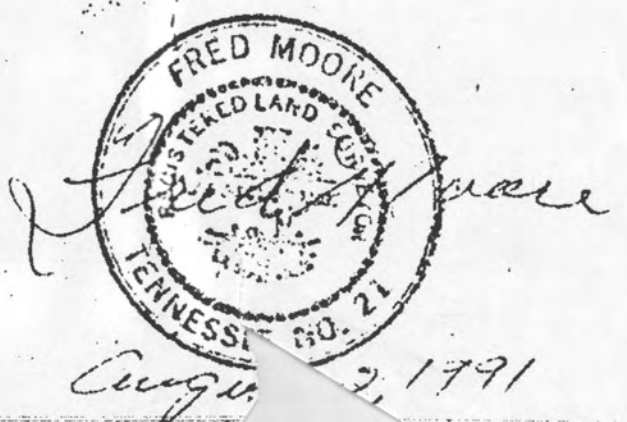

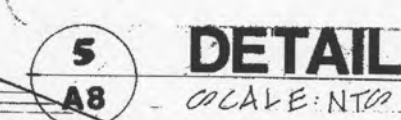


WEST ELEVATION
SCALE : 1/8" = 1'-0"

of 28 sheets.

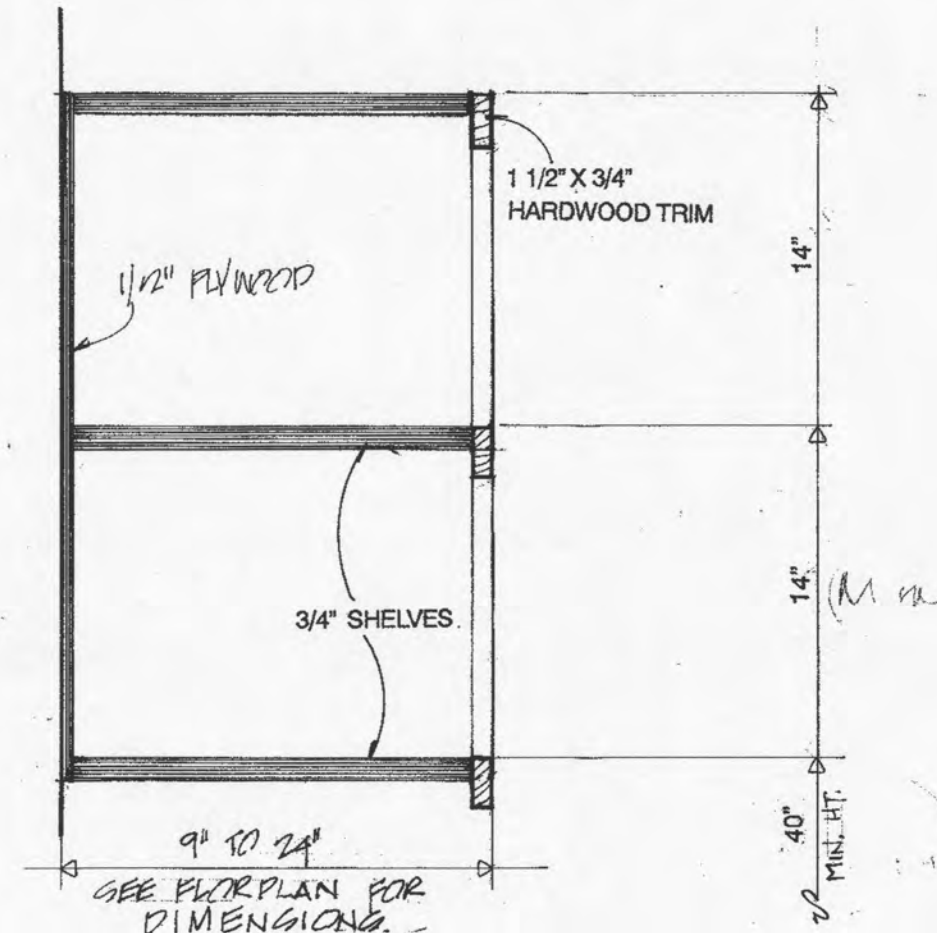


2 SHELVES DETAIL
A9 SCALE : NTS

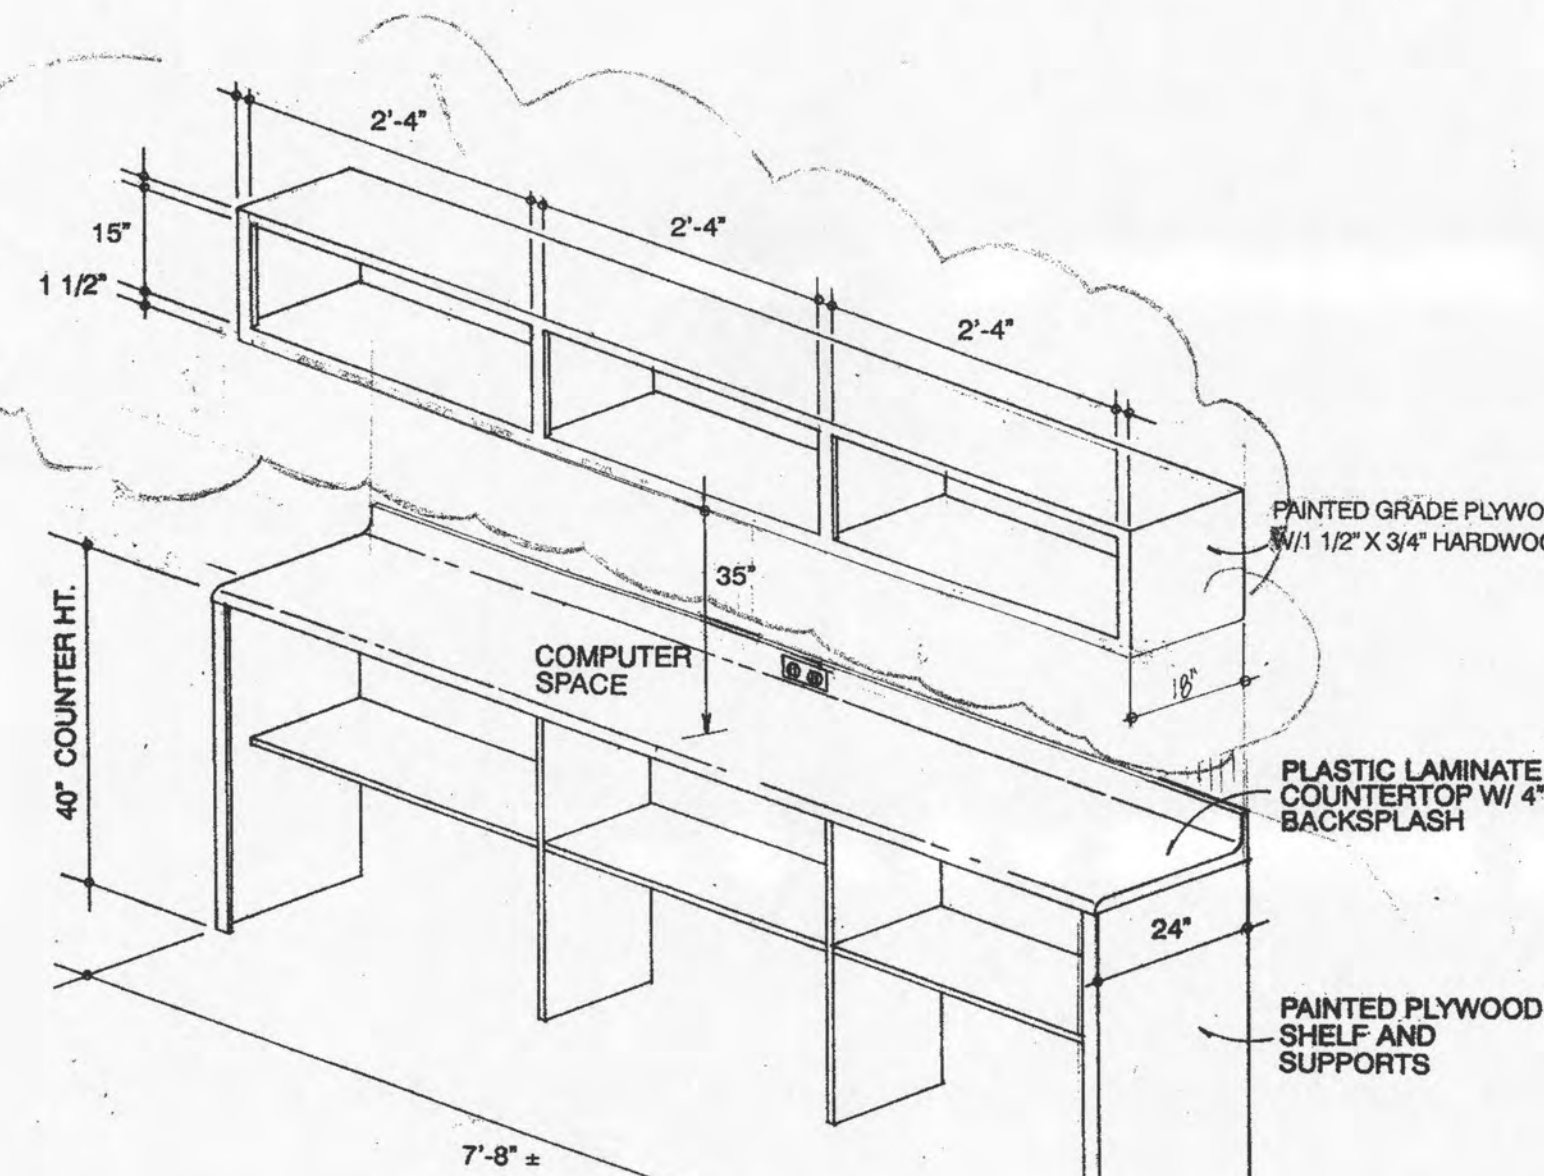


3 SHELVES @ CLOSET 307
A9 N.T.S.

SHELF SCHEDULE:


NO.	SHELF DEPTH	ROOM NO.	ROOM NAME
LEVEL I-			
3	12"	127	JANITOR
3	15"	132	COMPUTER ROOM
3	15"	133	VP ACCOUNTING
LEVEL II-			
3	15"	203	COPIER ROOM
3 & 5	15"	235	CASH VAULT
LEVEL III-			
5 & 5	9" & 24"	304	VP ACCOUNTING
3	15"	305	ACCOUNTING
3	15"	309	AVP-CREDIT
3	15"	321	COPIER ROOM

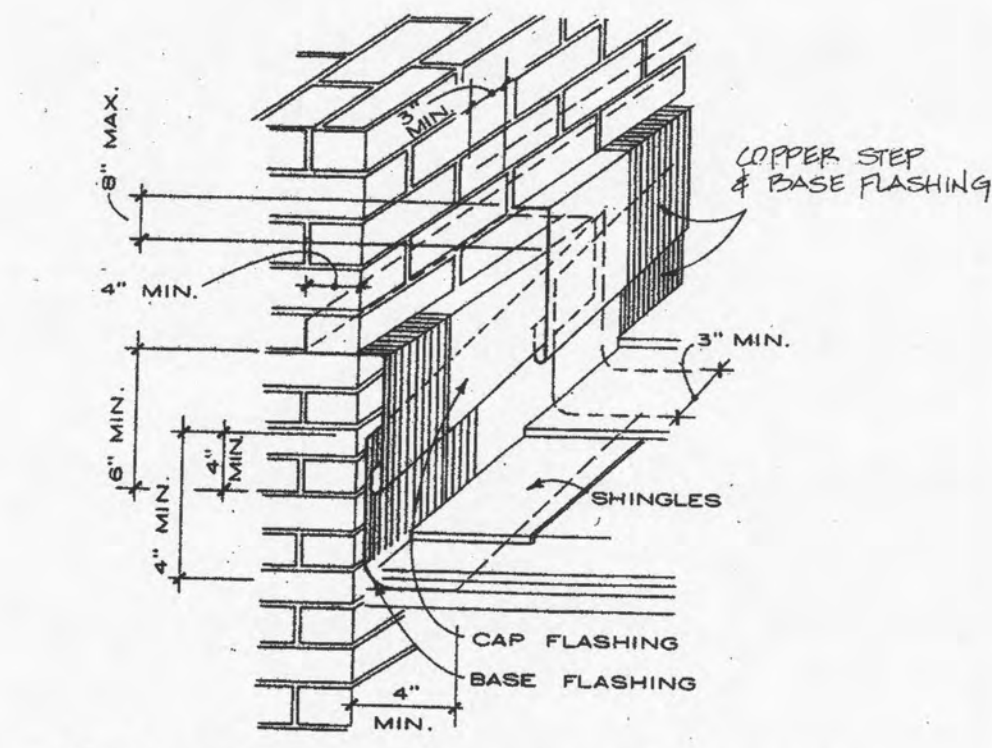


1 STEP FLASHING DETAIL
A-9 N.T.S.

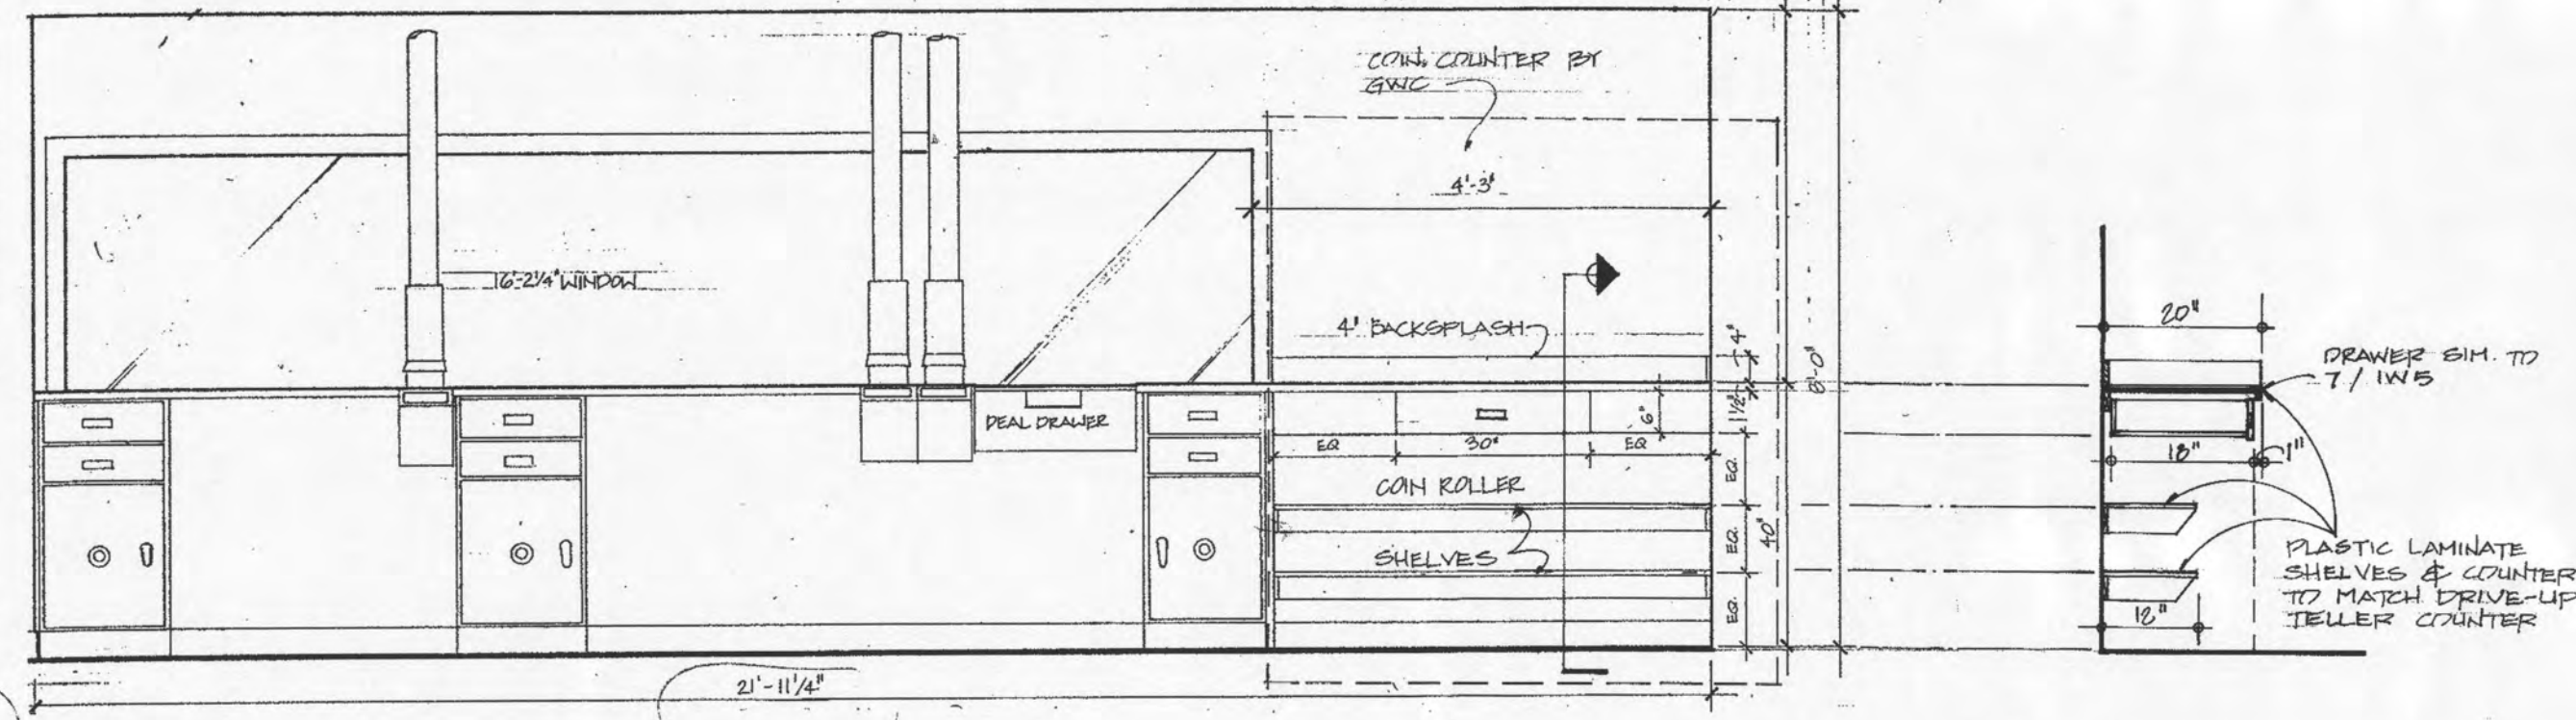


4 ELEVATION @ DRIVE UP TELLERS
A9 SCALE : NTS

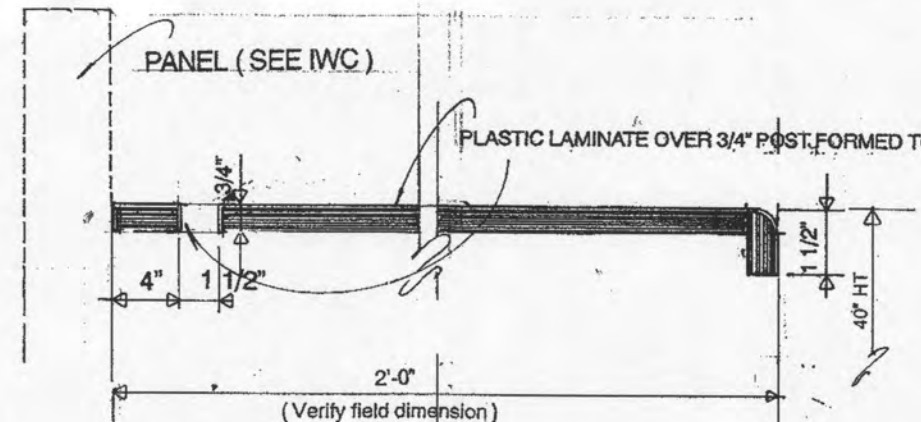


5 COUNTER DETAIL
A9 SCALE : NTS

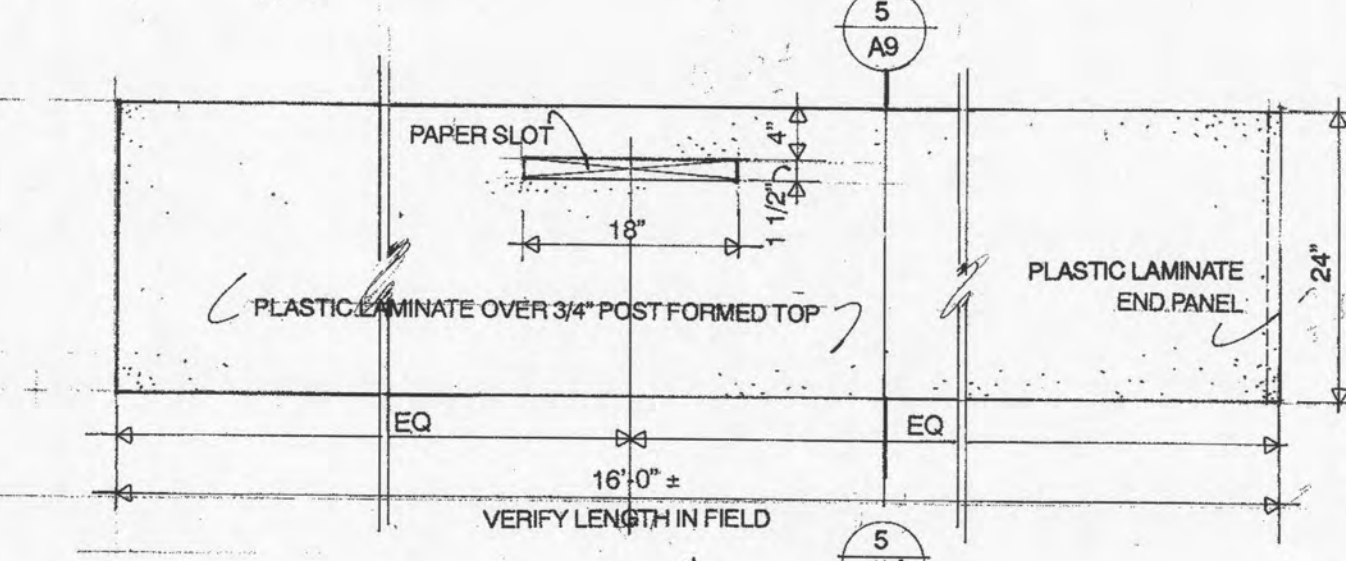

6 Countertop @ Credit & Loan Admin. # 308
A9 SCALE : NTS

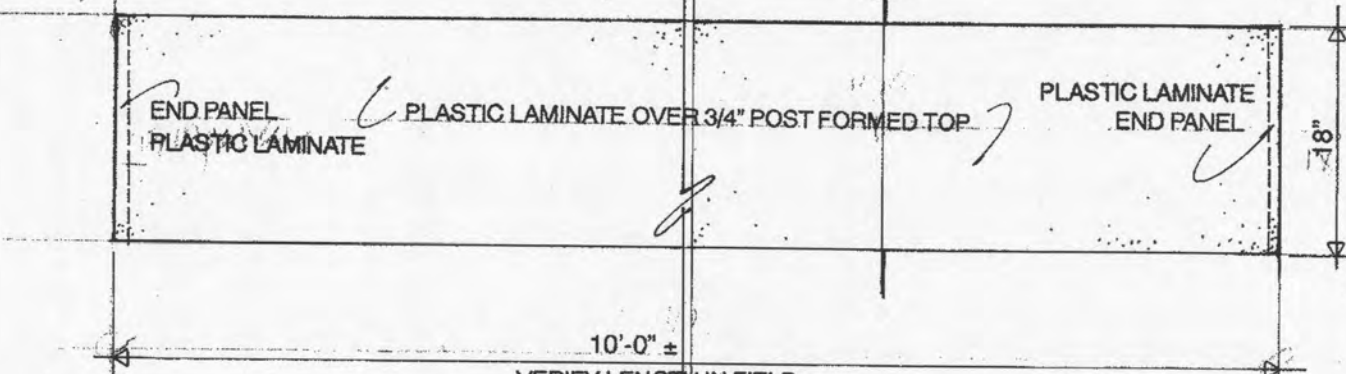

7 Countertop @ Record Vault # 311
A9 SCALE : NTS

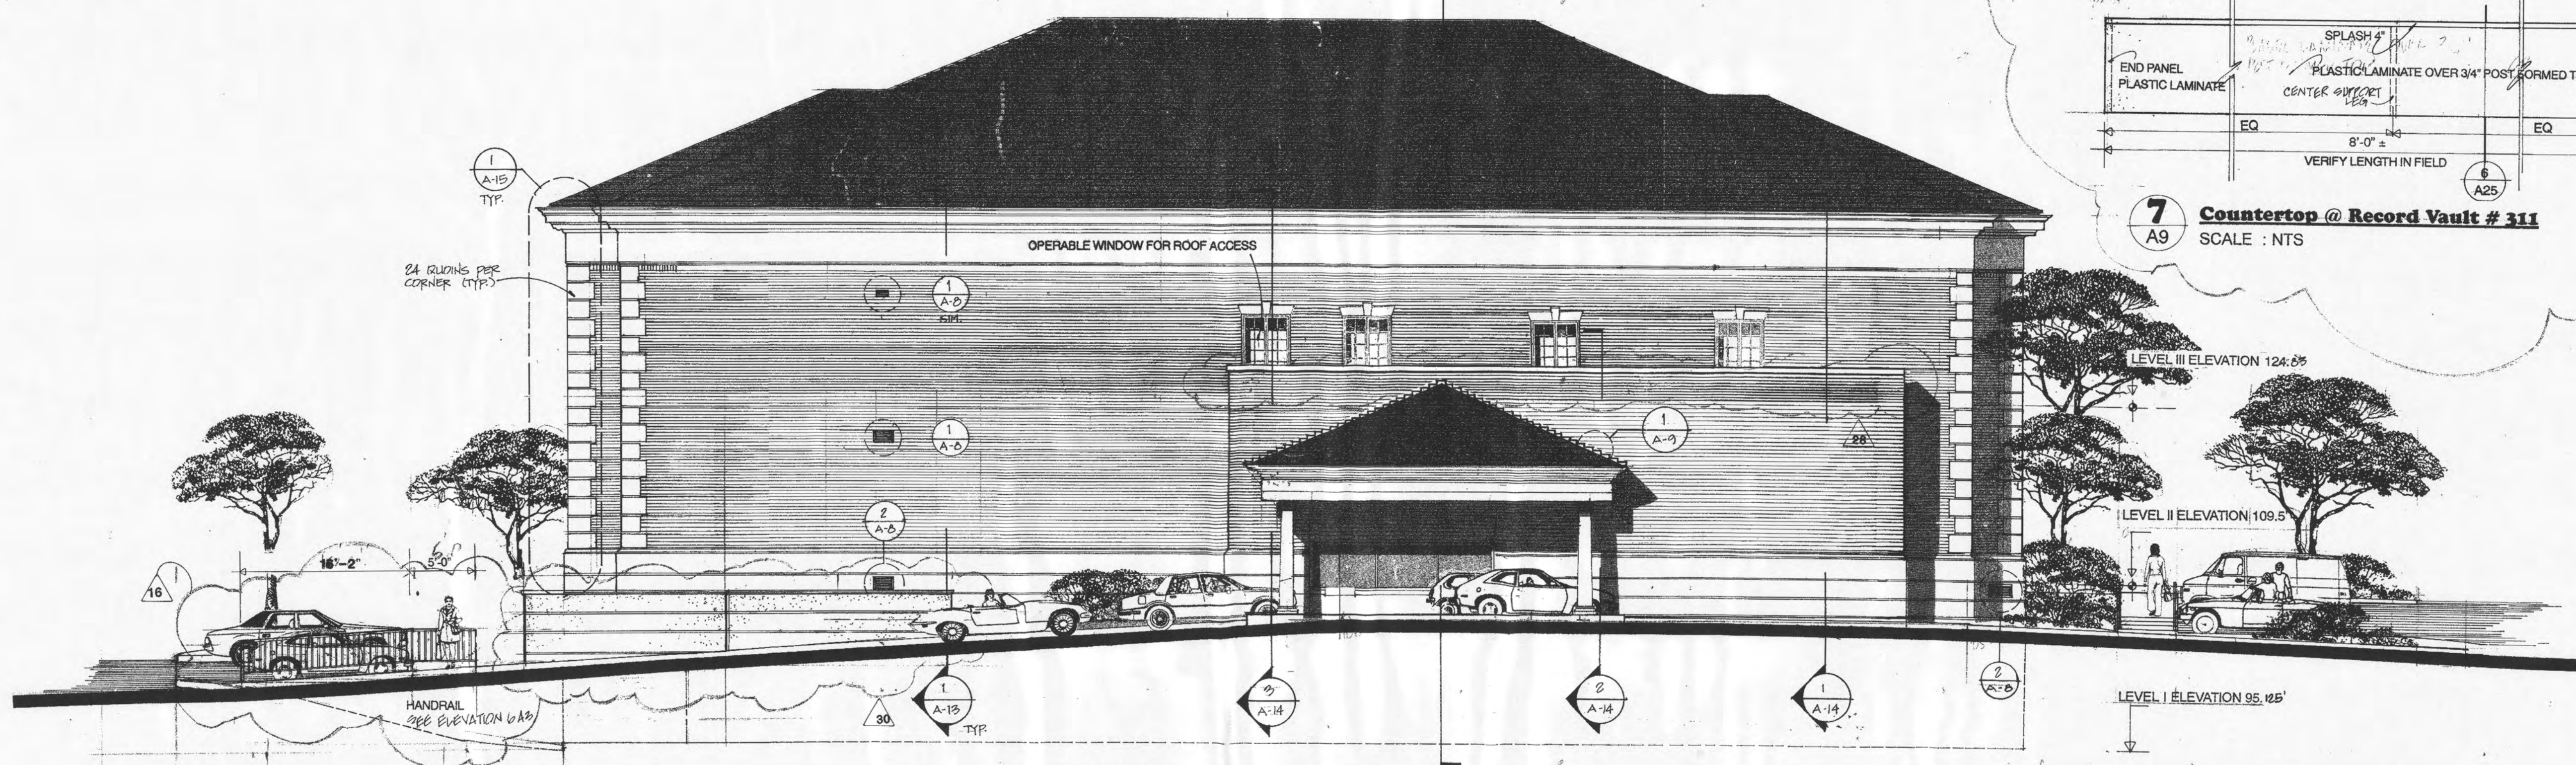

SOUTH ELEVATION
SCALE : 1/8" = 1'-0"

343

DATE	BY	REV
JULY 10, 1992	6	RGV
September 1992	15	RV
October 1992	23	RV
December 1992	28	RV
DECEMBER 14, 92	30	RV

Concepts

CONSULTANTS
DESIGNERS
CONSTRUCTION MANAGERS

DESIGN-BUILD
DESIGN-BUILD

3500 Roswell Road
Atlanta, Georgia 30329
404/252-0860

RELEASED FOR CONSTRUCTION

This drawing and the designs herein are the property of Design-Build Concepts, Inc. The design-build concepts, inc. documents, in whole or in part, for any purpose other than as shown herein, is prohibited.

DESIGN-BUILD CONCEPTS, INC.
1000 R. SMITH
NASHVILLE, TN 37203

REAR ELEVATION & DETAILS

A NEW MAIN OFFICE FACILITIES FOR:


Bank of Roane County
HARRIMAN, TENNESSEE

DATE: JUNE 10, 1992

SHEET

A-9


of 28 SHEETS

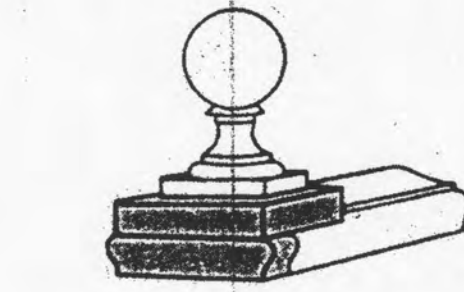


A MALLEABLE IRON
SQUARE BASE




B BASE

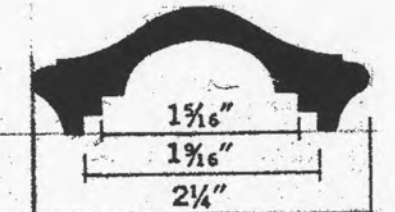

D HANDRAIL MOULDING

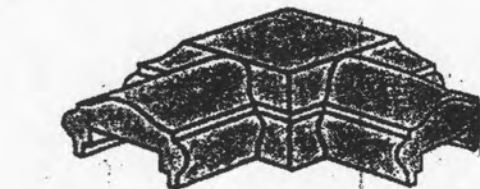

C UL CORNER

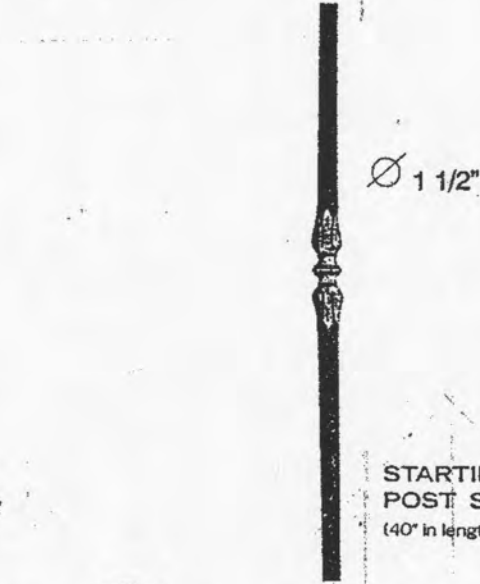


E STARTING POST

JULIUS BLUM & CO. OR SIMILAR


1 HANDRAIL PARTIAL ELEVATION
A-10 SCALE: 1" = 1'-0"



 
DET. A




DET. B

 


DET. C

 


DET. D

 


DET. E

 


DET. F

 


DET. G

 


DET. H

 


DET. I

 


DET. J

 


DET. K

 


DET. L

 


DET. M

 


DET. N

 


DET. O

 


DET. P

 


DET. Q

 


DET. R

 


DET. S

 


DET. T

 


DET. U

 


DET. V

 


DET. W

 


DET. X

 


DET. Y

 


DET. Z

 


DET. AA

 


DET. AB

 


DET. AC

 


DET. AD

 


DET. AE

 


DET. AF

 


DET. AG

 


DET. AH

 


DET. AI

 


DET. AJ

 


DET. AK

 


DET. AL

 


DET. AM

 


DET. AN

 


DET. AO

 


DET. AP

 


DET. AQ

 


DET. AR

 


DET. AS

 


DET. AT

 


DET. AU

 


DET. AV

 


DET. AW

 


DET. AX

 


DET. AY

 


DET. AZ

 


DET. BA

 


DET. BB

 


DET. BC

 


DET. BD

 


DET. BE

 


DET. BF

 


DET. BG

 


DET. BH

 


DET. BI

 


DET. BJ

 


DET. BK

 


DET. BL

 


DET. BM

 


DET. BN

 


DET. BO

 


DET. BP

 


DET. BQ

 


DET. BR

 


DET. BS

 


DET. BT

 


DET. BU

 


DET. BV

 


DET. BW

 


DET. BX

 


DET. BY

 


DET. BZ

 


DET. CA

 


DET. CB

 


DET. CC

 


DET. CD

 


DET. CE

 


DET. CF

 


DET. CG

 


DET. CH

 


DET. CI

 


DET. CJ

 


DET. CK

 


DET. CL

 


DET. CM

 


DET. CN

 


DET. CO

 


DET. CP

 


DET. CQ

 


DET. CR

 


DET. CS

 


DET. CT

 


DET. CU

 


DET. CV

 


DET. CW

 


DET. CX

 


DET. CY

 


DET. CZ

 


DET. DA

 


DET. DB

 


DET. DC

 


DET. DD

 


DET. DE

 


DET. DF

 


DET. DG

 


DET. DH

 


DET. DI

 


DET. DJ

 


DET. DK

 


DET. DL

 


DET. DM

 


DET. DN

 


DET. DO

 


DET. DP

 


DET. DQ

 


DET. DR

 


DET. DS

 

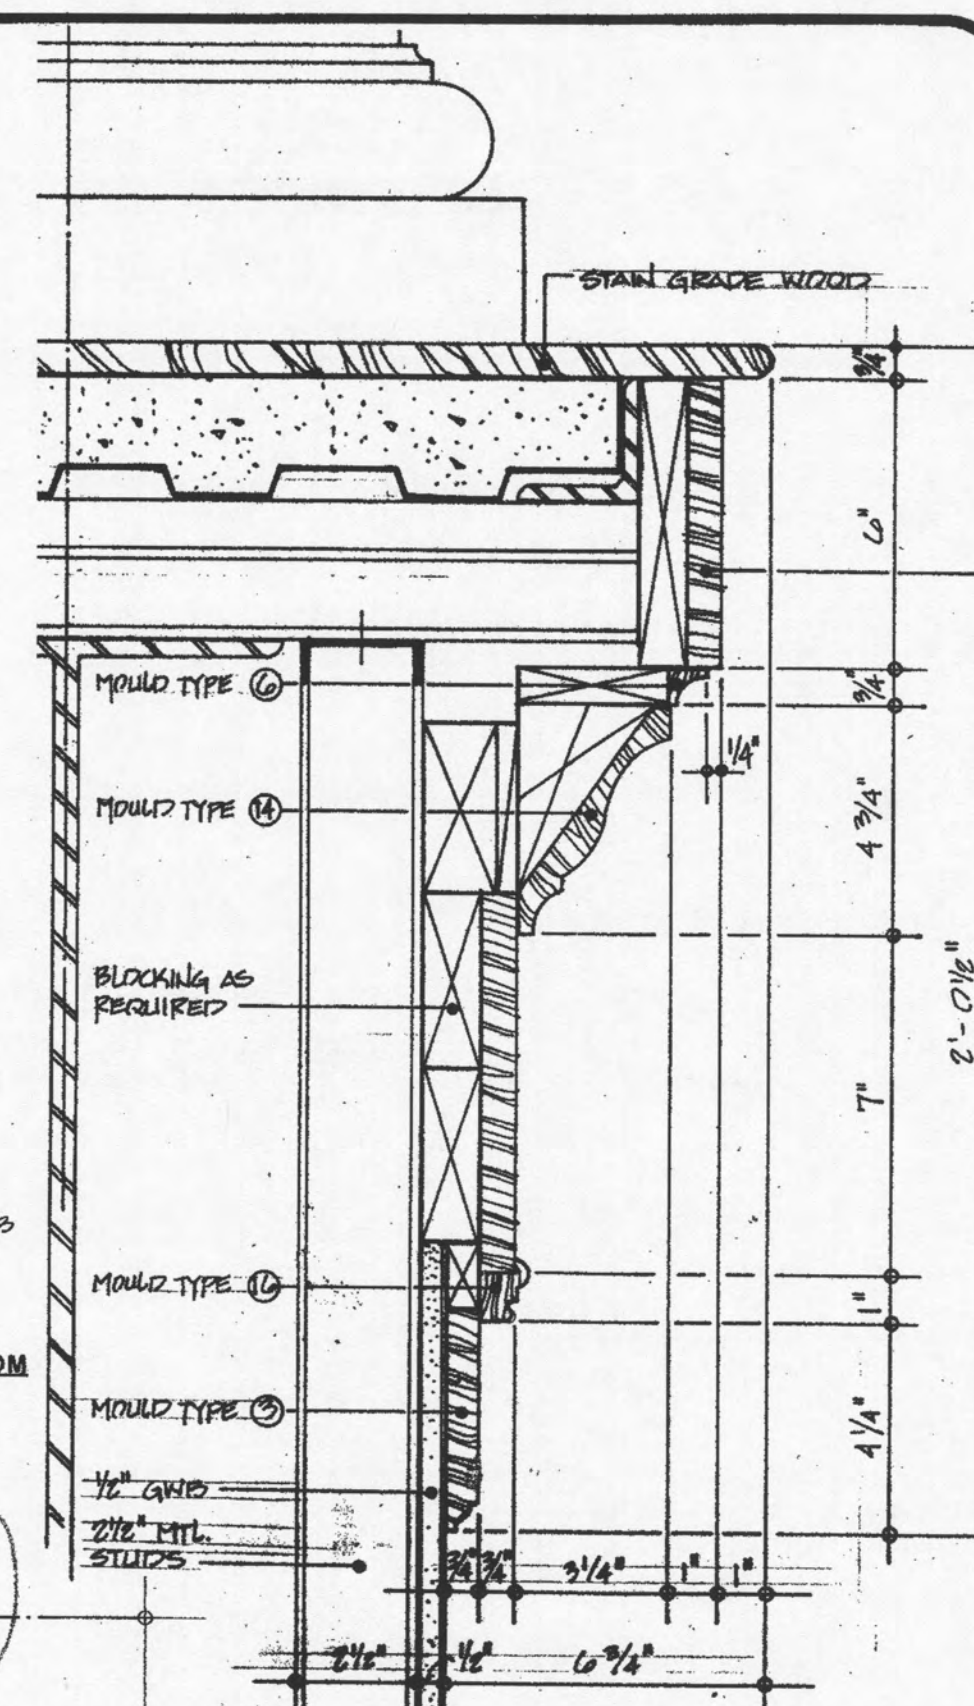

BUILDING SECTION

1
A-11 SCALE: 1/4" = 1'-0"

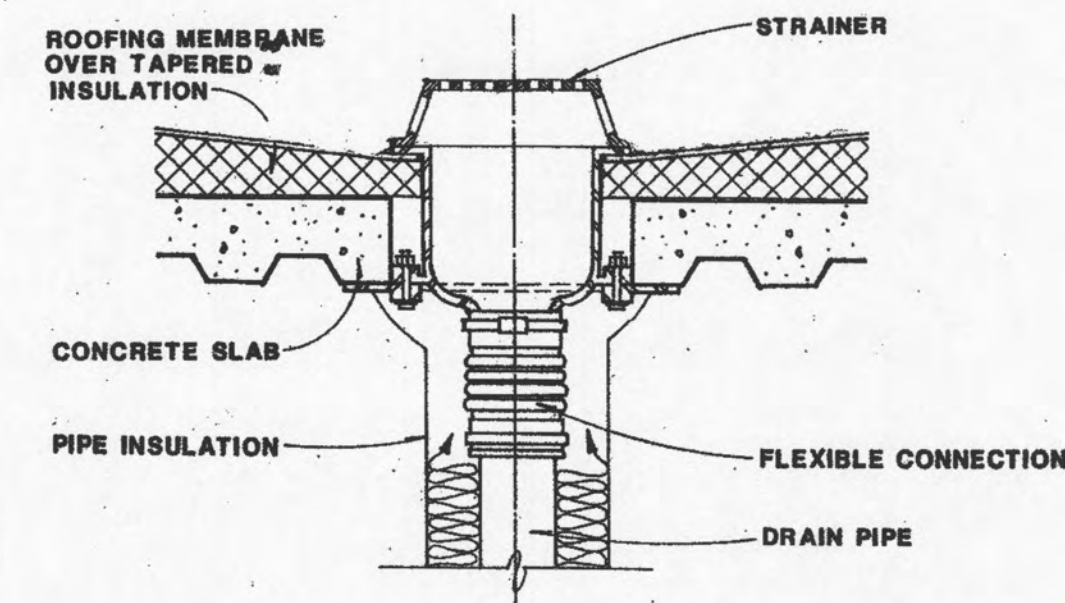

2 ROOF DRAIN DETAIL
A-12 N.T.S.

BUILDING SECTION

1
A-12 SCALE: 1/4" = 1'-0"

sheet description

A NEW MAIN OFFICE FACILITY FOR :

Bank of Roane County
HARRIMAN, TENNESSEE

HARRIMAN,

APPROVED

RELEASED FOR CONSTRUCTION

THE STATE OF CALIFORNIA
COUNTY OF SAN DIEGO

NOTARY PUBLIC

ROBERT R. SMITH
NOTARY PUBLIC
No. 123456
EXPIRES 12/31/98

[Signature]

Design Build Concepts Inc. The
reproduction or use of these
plans for any purpose other than as
specifically authorized by
Design Build Concepts Inc. in
writing is prohibited.

design·build
design·build
design·build
design·build

Concepts


- Consultants
- Designers
- Construction Managers

5187 Roswell Road
Atlanta Georgia 30342


404 256-0960

described by CK	drawn by GRI
--------------------	-----------------


WORKING
POINT 31'-0" A.F.F.
DE 1000 II

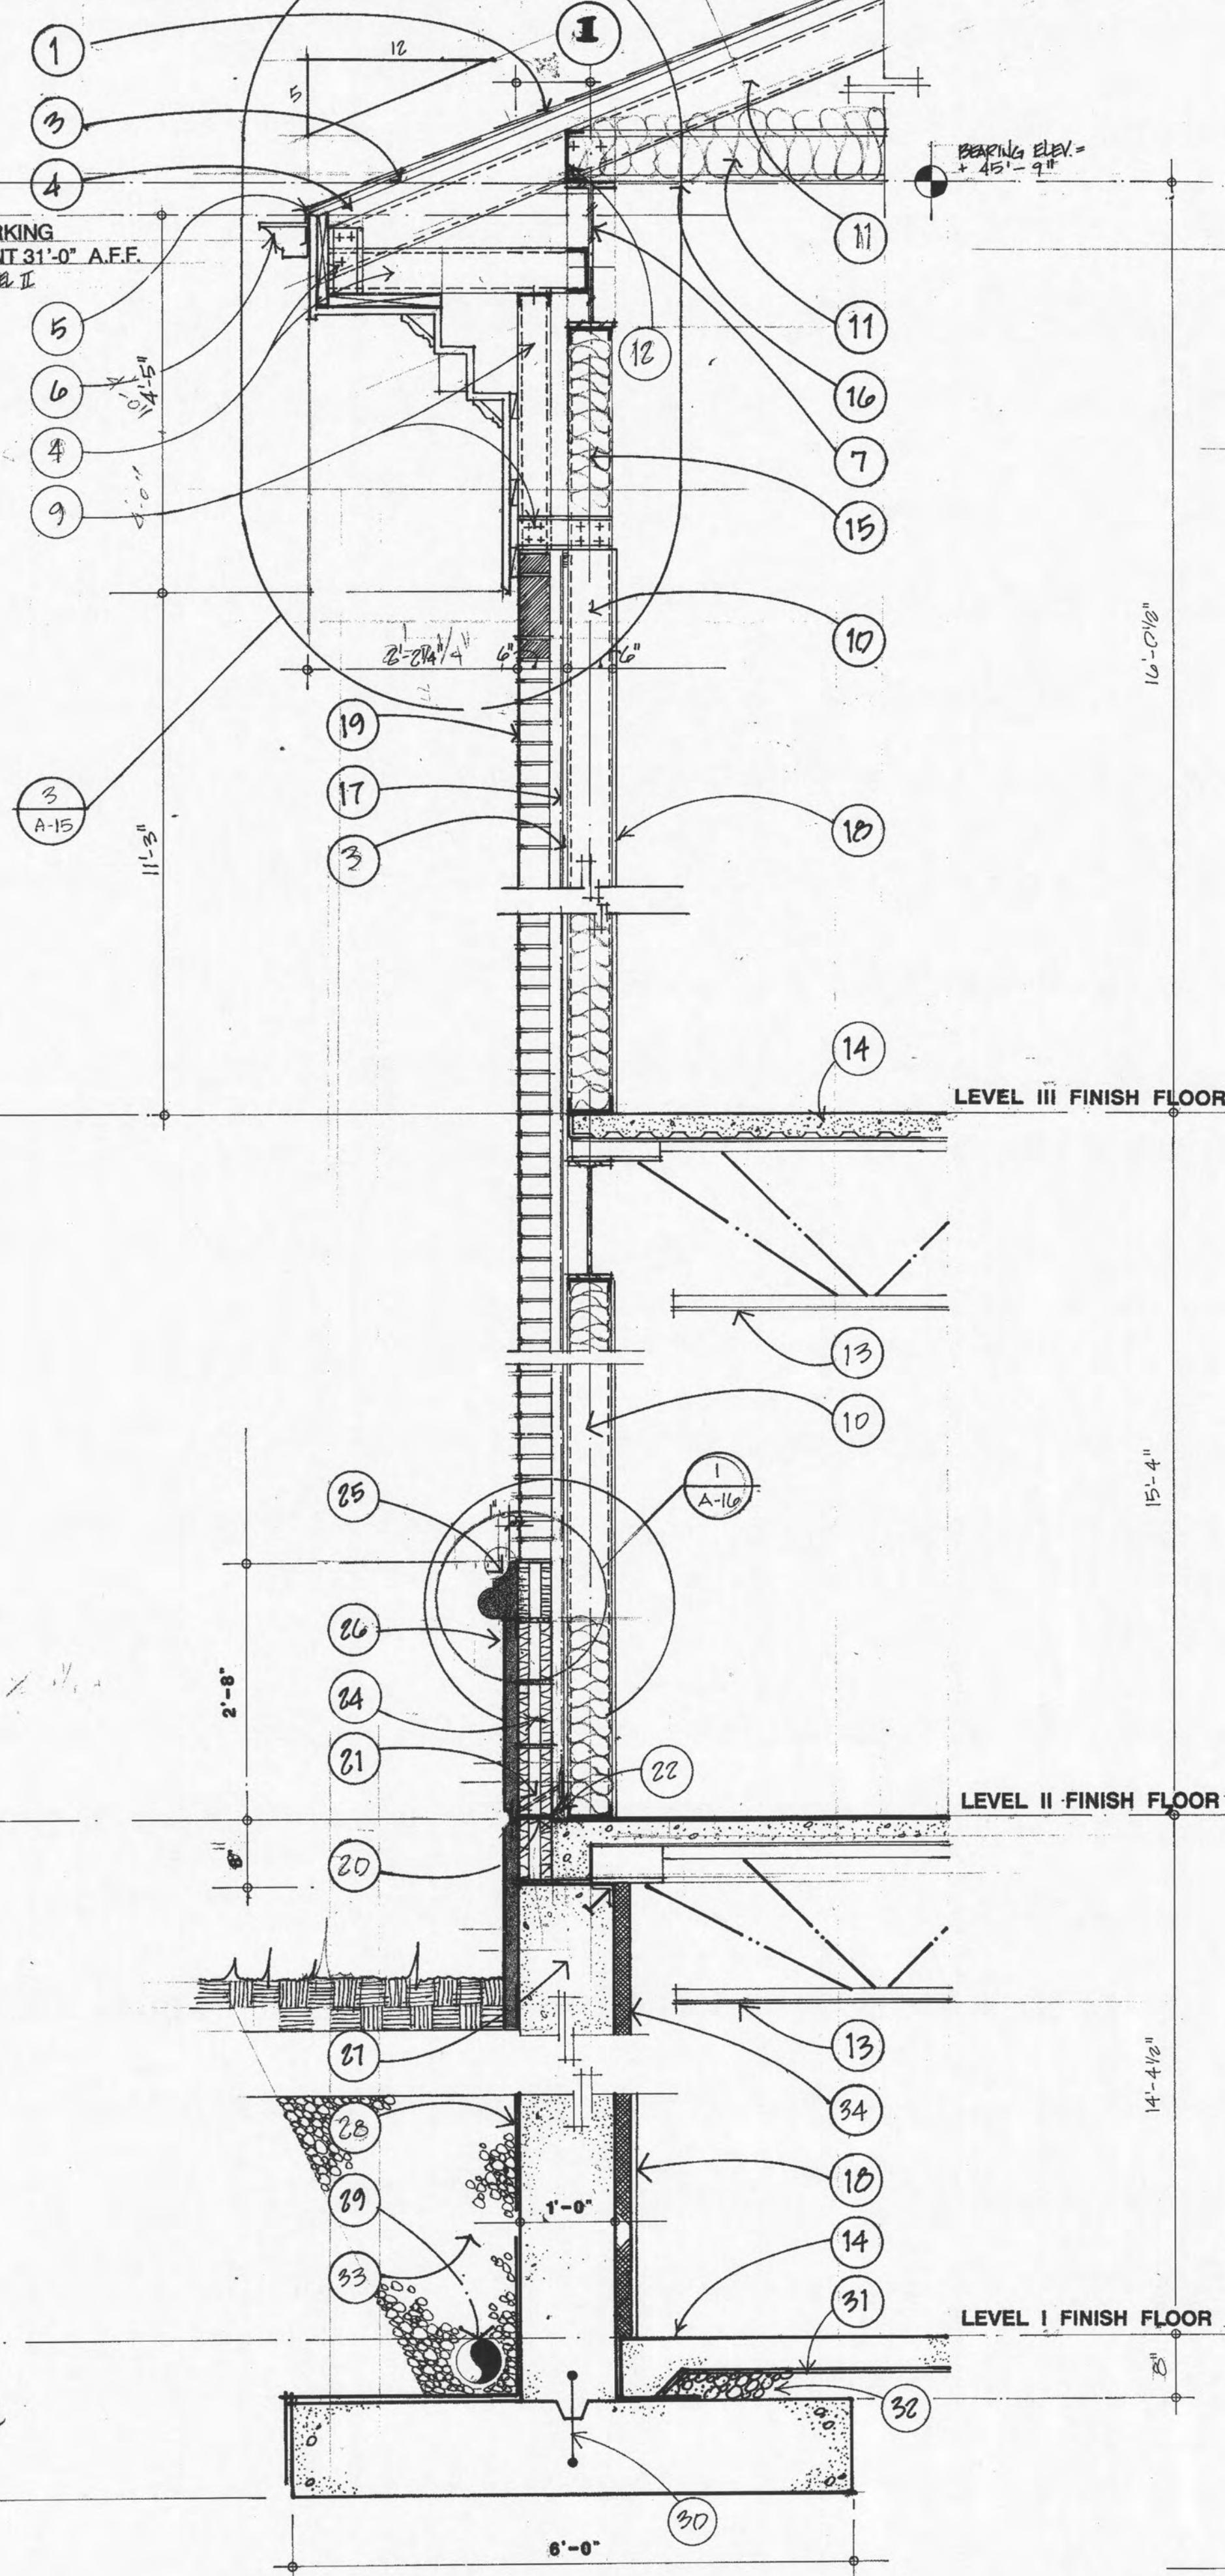

1 WALL SECTION
A-13 SCALE: 3/4"=1'-0"

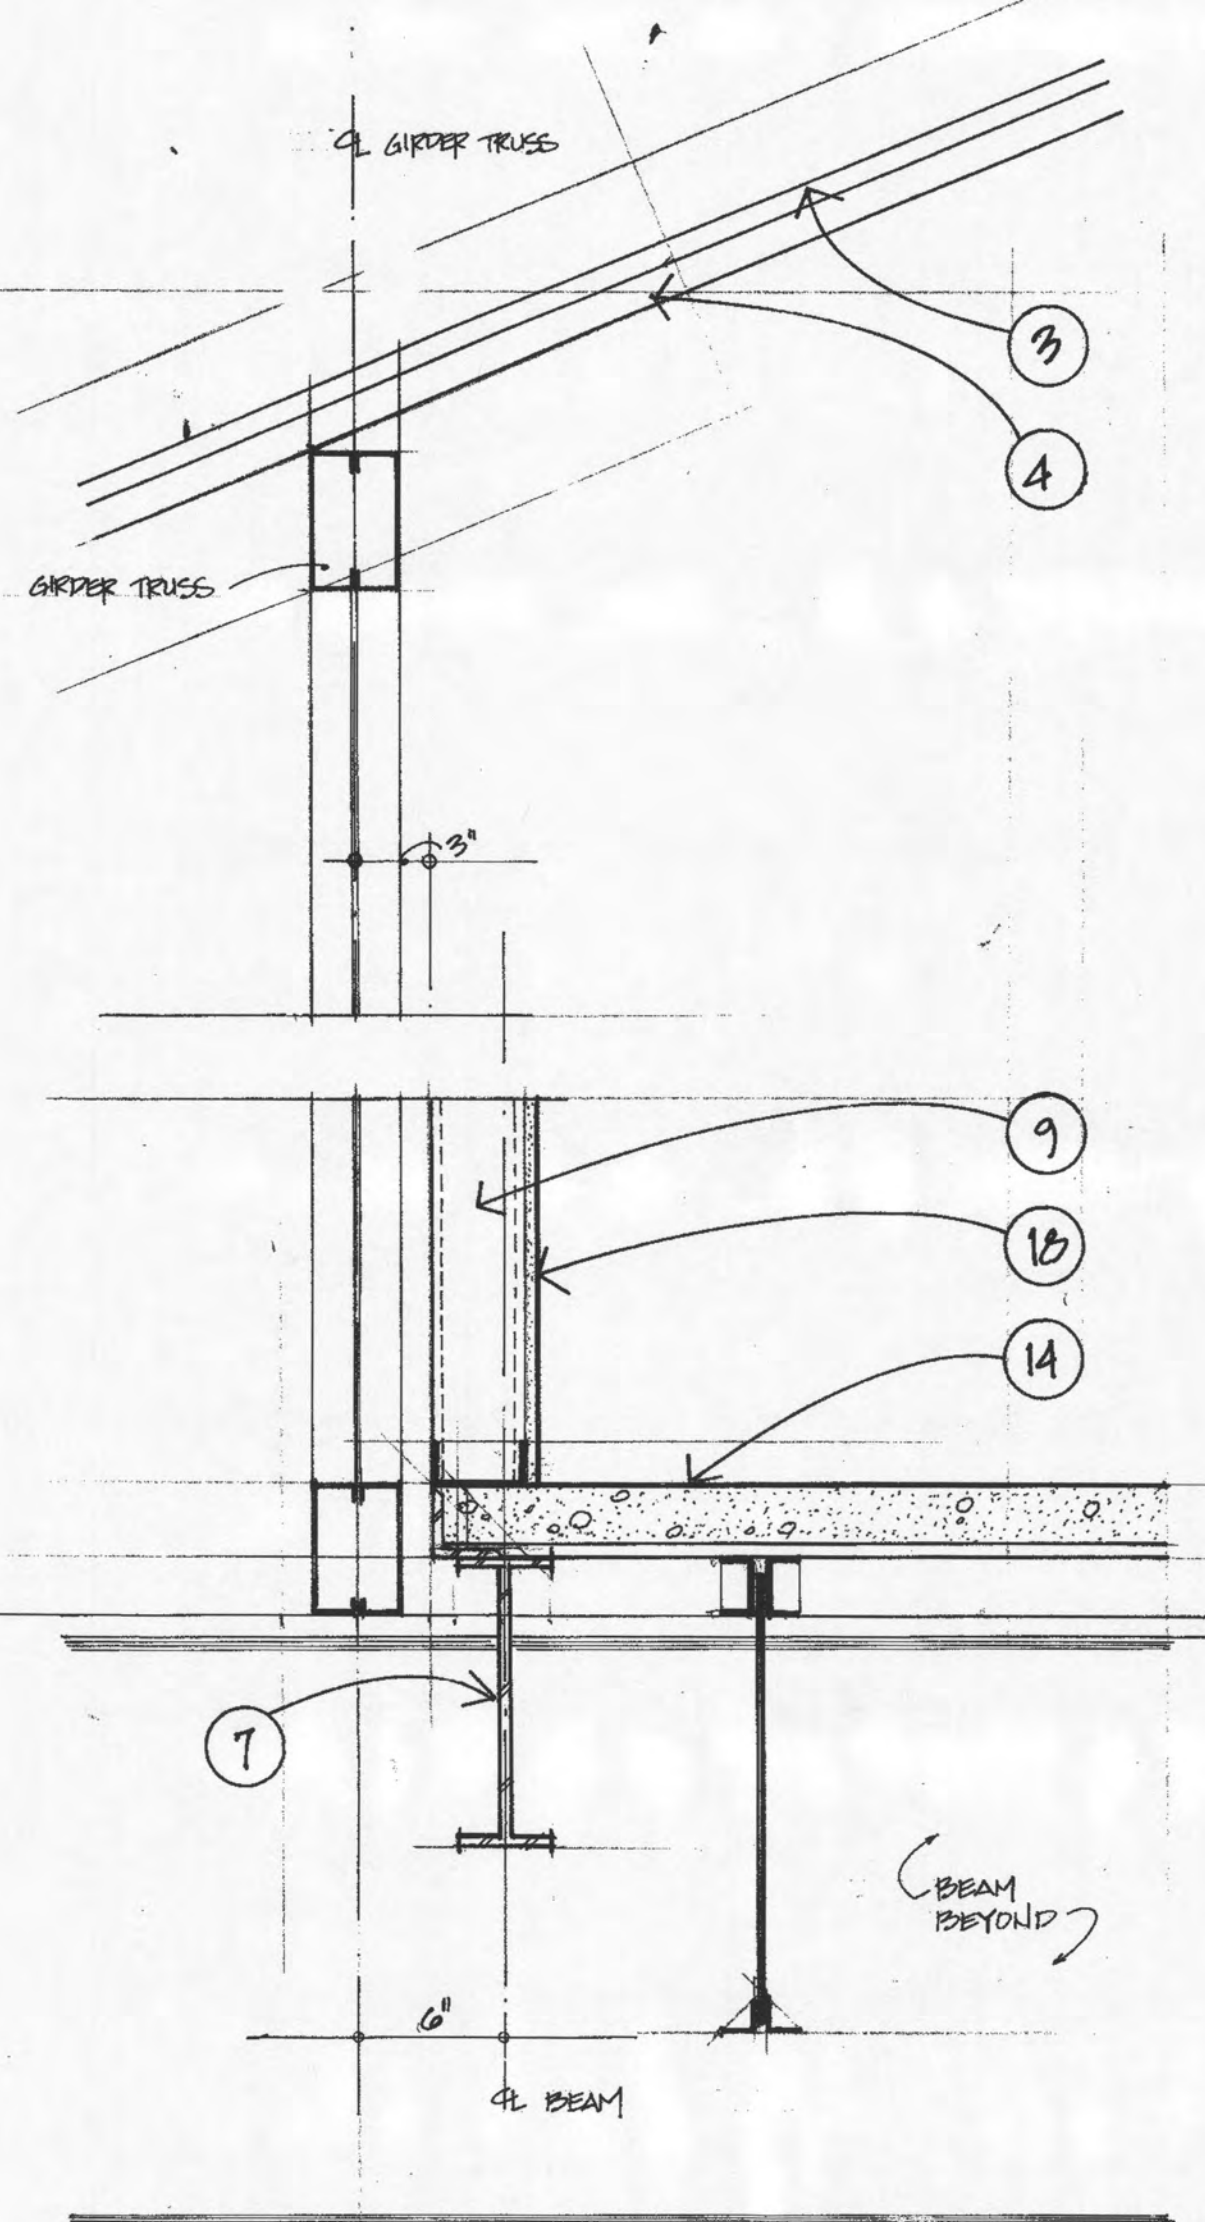


2 SECTION DETAIL
A-13 SCALE: 1 1/2"=1'-0"

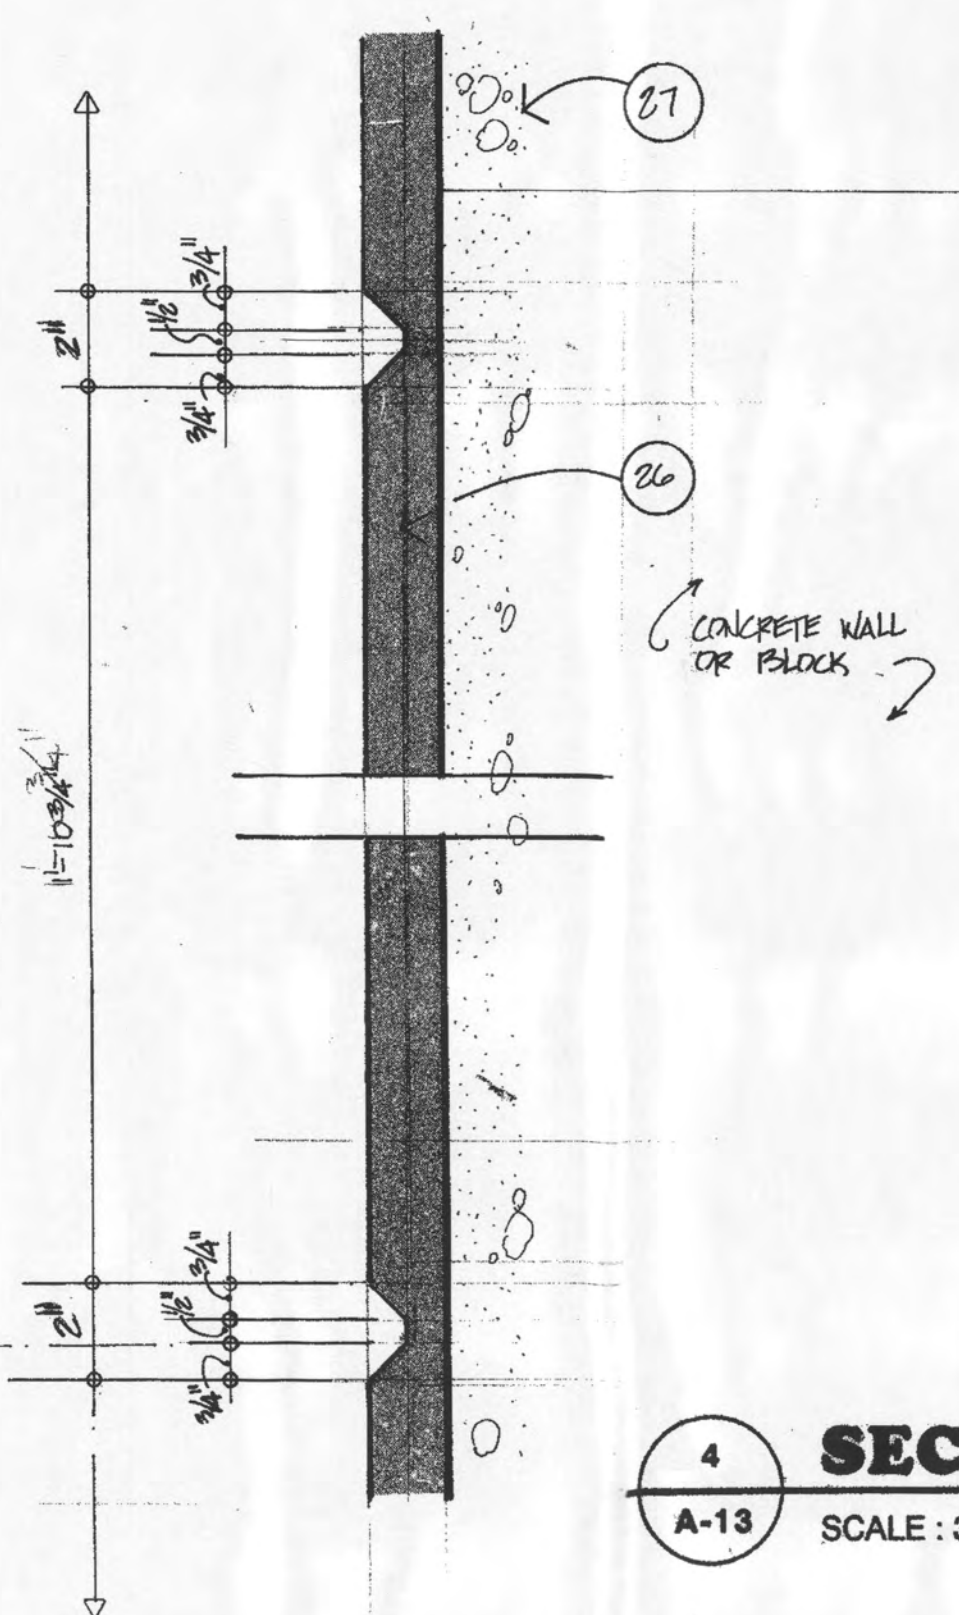

4 SECTION DETAIL
A-13 SCALE: 3"=1'-0"

LEGEND

1. ASPHALT SHINGLES
2. FELT PAPER
3. 1/2" EXTERIOR SHEATHING
4. 1 1/2" DEEP METAL DECK
5. PREFINISHED DRIP EDGE
6. PREFINISHED ALUMINUM GUTTER
7. STEEL BEAM (SEE STRUCT. DRWG.)
8. 4" MTL. STUDS @ 9" O.C.
9. 4" MTL. STUDS @ 16" O.C.
10. 8" MTL. STUDS @ 16" O.C.
11. STEEL TRUSSES @ 5'-0" MAX. O.C. (SEE STRUCT. DRWG.)
12. C-JOIST BLOCKING BETWEEN TRUSSES
13. STEEL JOIST (SEE STRUCT. DRWG.)
14. CONCRETE SLAB
15. 6" BATT INSULATION
16. 2" BATT INSULATION W/ SUPPORT NET
17. 1/2" EXTERIOR SHEATHING
18. 1/2" INTERIOR GWS
19. BROCK VENEER W/ MTL. TIES @ 16" O.C.
20. THRUWALL FLASHING
21. WEEP HOLES @ 4'-0" O.C.
22. GROUT SOLID
23. 4" NOMINAL CONC. BLOCK
24. 8" NOMINAL CONC. BLOCK
25. SPECIAL SHAPE EXTERIOR FINISH SYSTEM
26. EXTERIOR FINISH SYSTEM OVER 1/2" RIGID INSULATION
27. CONC. FOUNDATION WALLS (SEE STRUCT. DRWG.)
28. WATER-PROOF MEMBRANE W/ 1" PROTECTIVE BOARD
29. 8" PERFORATED CORRUGATED PLASTIC TUBE FOOTING DRAIN WRAPPED IN FILTER PLASTIC
30. WATER STOP
31. VAPOR BARRIER
32. 4" GRAVEL
33. 8" STONE
34. 1 1/2" RIGID INSULATION ON Z FURRING
35. 12" VAULT WALL
36. 12" VAULT CEILING
37. SPRAY-TEXTURE PAINT
38. 6" X 2 1/2" X 1/8" CONT. TUBE
39. PRECAST STONE COPING
40. SINGLE-PLY ROOFING MEMBRANE
41. SINGLE-PLY FLASHING MEMBRANE
42. TAPERED RIGID ROOF INSULATION
43. 12" CONCRETE CURB
44. BACK-UP ROD AND SEALANT

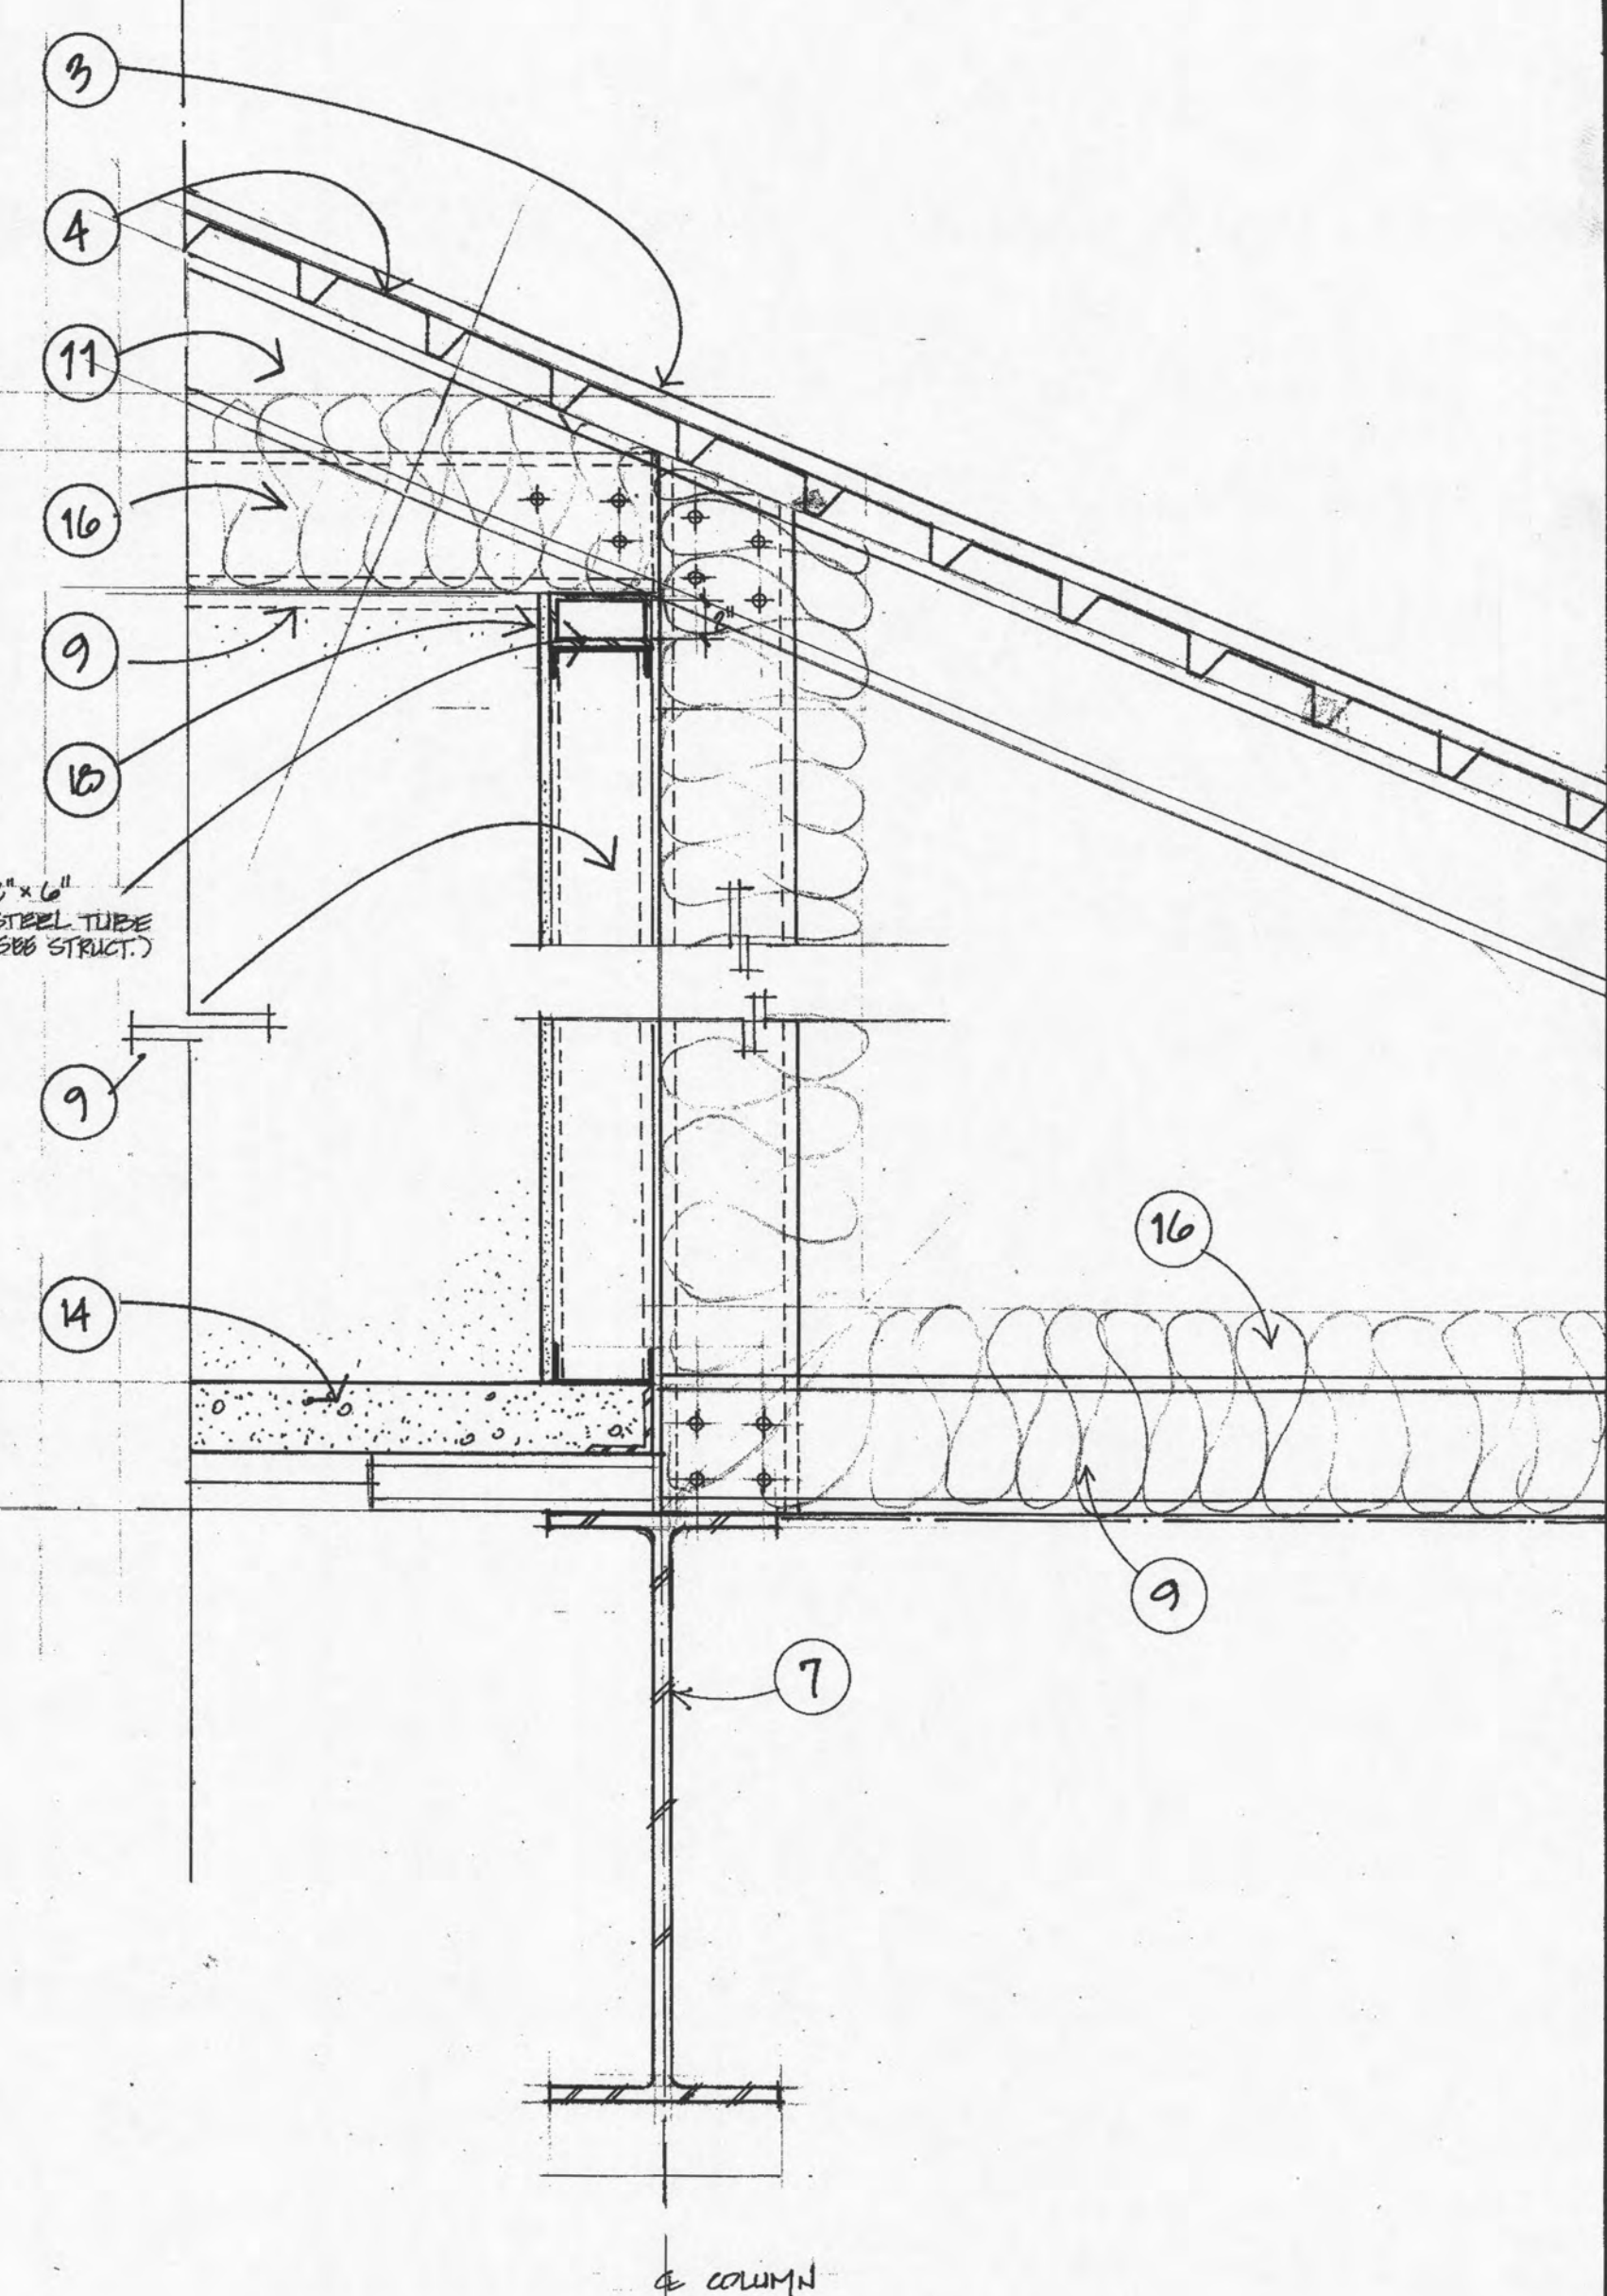

3 SECTION DETAIL
A-13 SCALE: 1 1/2"=1'-0"

Approved Assemblies
Wall Assembly—U.L. System No. 510
F Rating—2 hr.

Section A-A

5 FIRESTOP
A13 SCALE: NTS.

1. Wall Assembly—Any 2-hr. fire-resistant gypsum panel wall assembly. Joints treated with SKEETPROOF Joint Tape; joints and fasteners treated with SKEETPROOF Joint Compound.
2. A nominal 4" diameter (or smaller) PVC pipe through-penetration firestop system has been evaluated and tested by Underwriters Laboratories Inc. as U.L. System No. 510. The system combines FIRECODE Compound and THERMAFIBER Safety Insulation with a hard-party insulating wrap to provide adequate protection in a 2-hr. fire-resistant gypsum panel wall assembly.
3. Cable—As an option to No. 2, min. 10% to max. 40% fill of max. 100 pair No. 24 AWG. telephone cables with polyvinyl chloride insulation and jacket. Cables to be rigidly supported on both sides of wall assembly. The annular space between the cables and the periphery of the opening may range from a max. 3/8" to 2" max. gap.
4. Filling Material—Min. 5" of THERMAFIBER Mineral Safety Insulation with min. density of 3.5 pcf—U.L. P-10000 label.
5. Fill, Void or Cavity Material—Min. 1" depth of FIRECODE Compound.

DATE: JUNE 10, 1992
SHEET: 1 OF 28 SHEETS
A-13

Concepts
design-build
design-build
design-build

Released for Construction
The design-build team consists of the architect, engineer, and construction manager. The design-build team is responsible for the design and construction of the project. The design-build team is responsible for the design and construction of the project.

Released for Construction
The design-build team consists of the architect, engineer, and construction manager. The design-build team is responsible for the design and construction of the project. The design-build team is responsible for the design and construction of the project.




WALL SECTIONS / DETAILS

A NEW MAIN OFFICE FACILITIES FOR:


Bank of Roane County
HARRIMAN, TENNESSEE

DATE: JUNE 10, 1992
SHEET: 1 OF 28 SHEETS
A-13


15'-4" 15'-4" 14'-4 1/2"

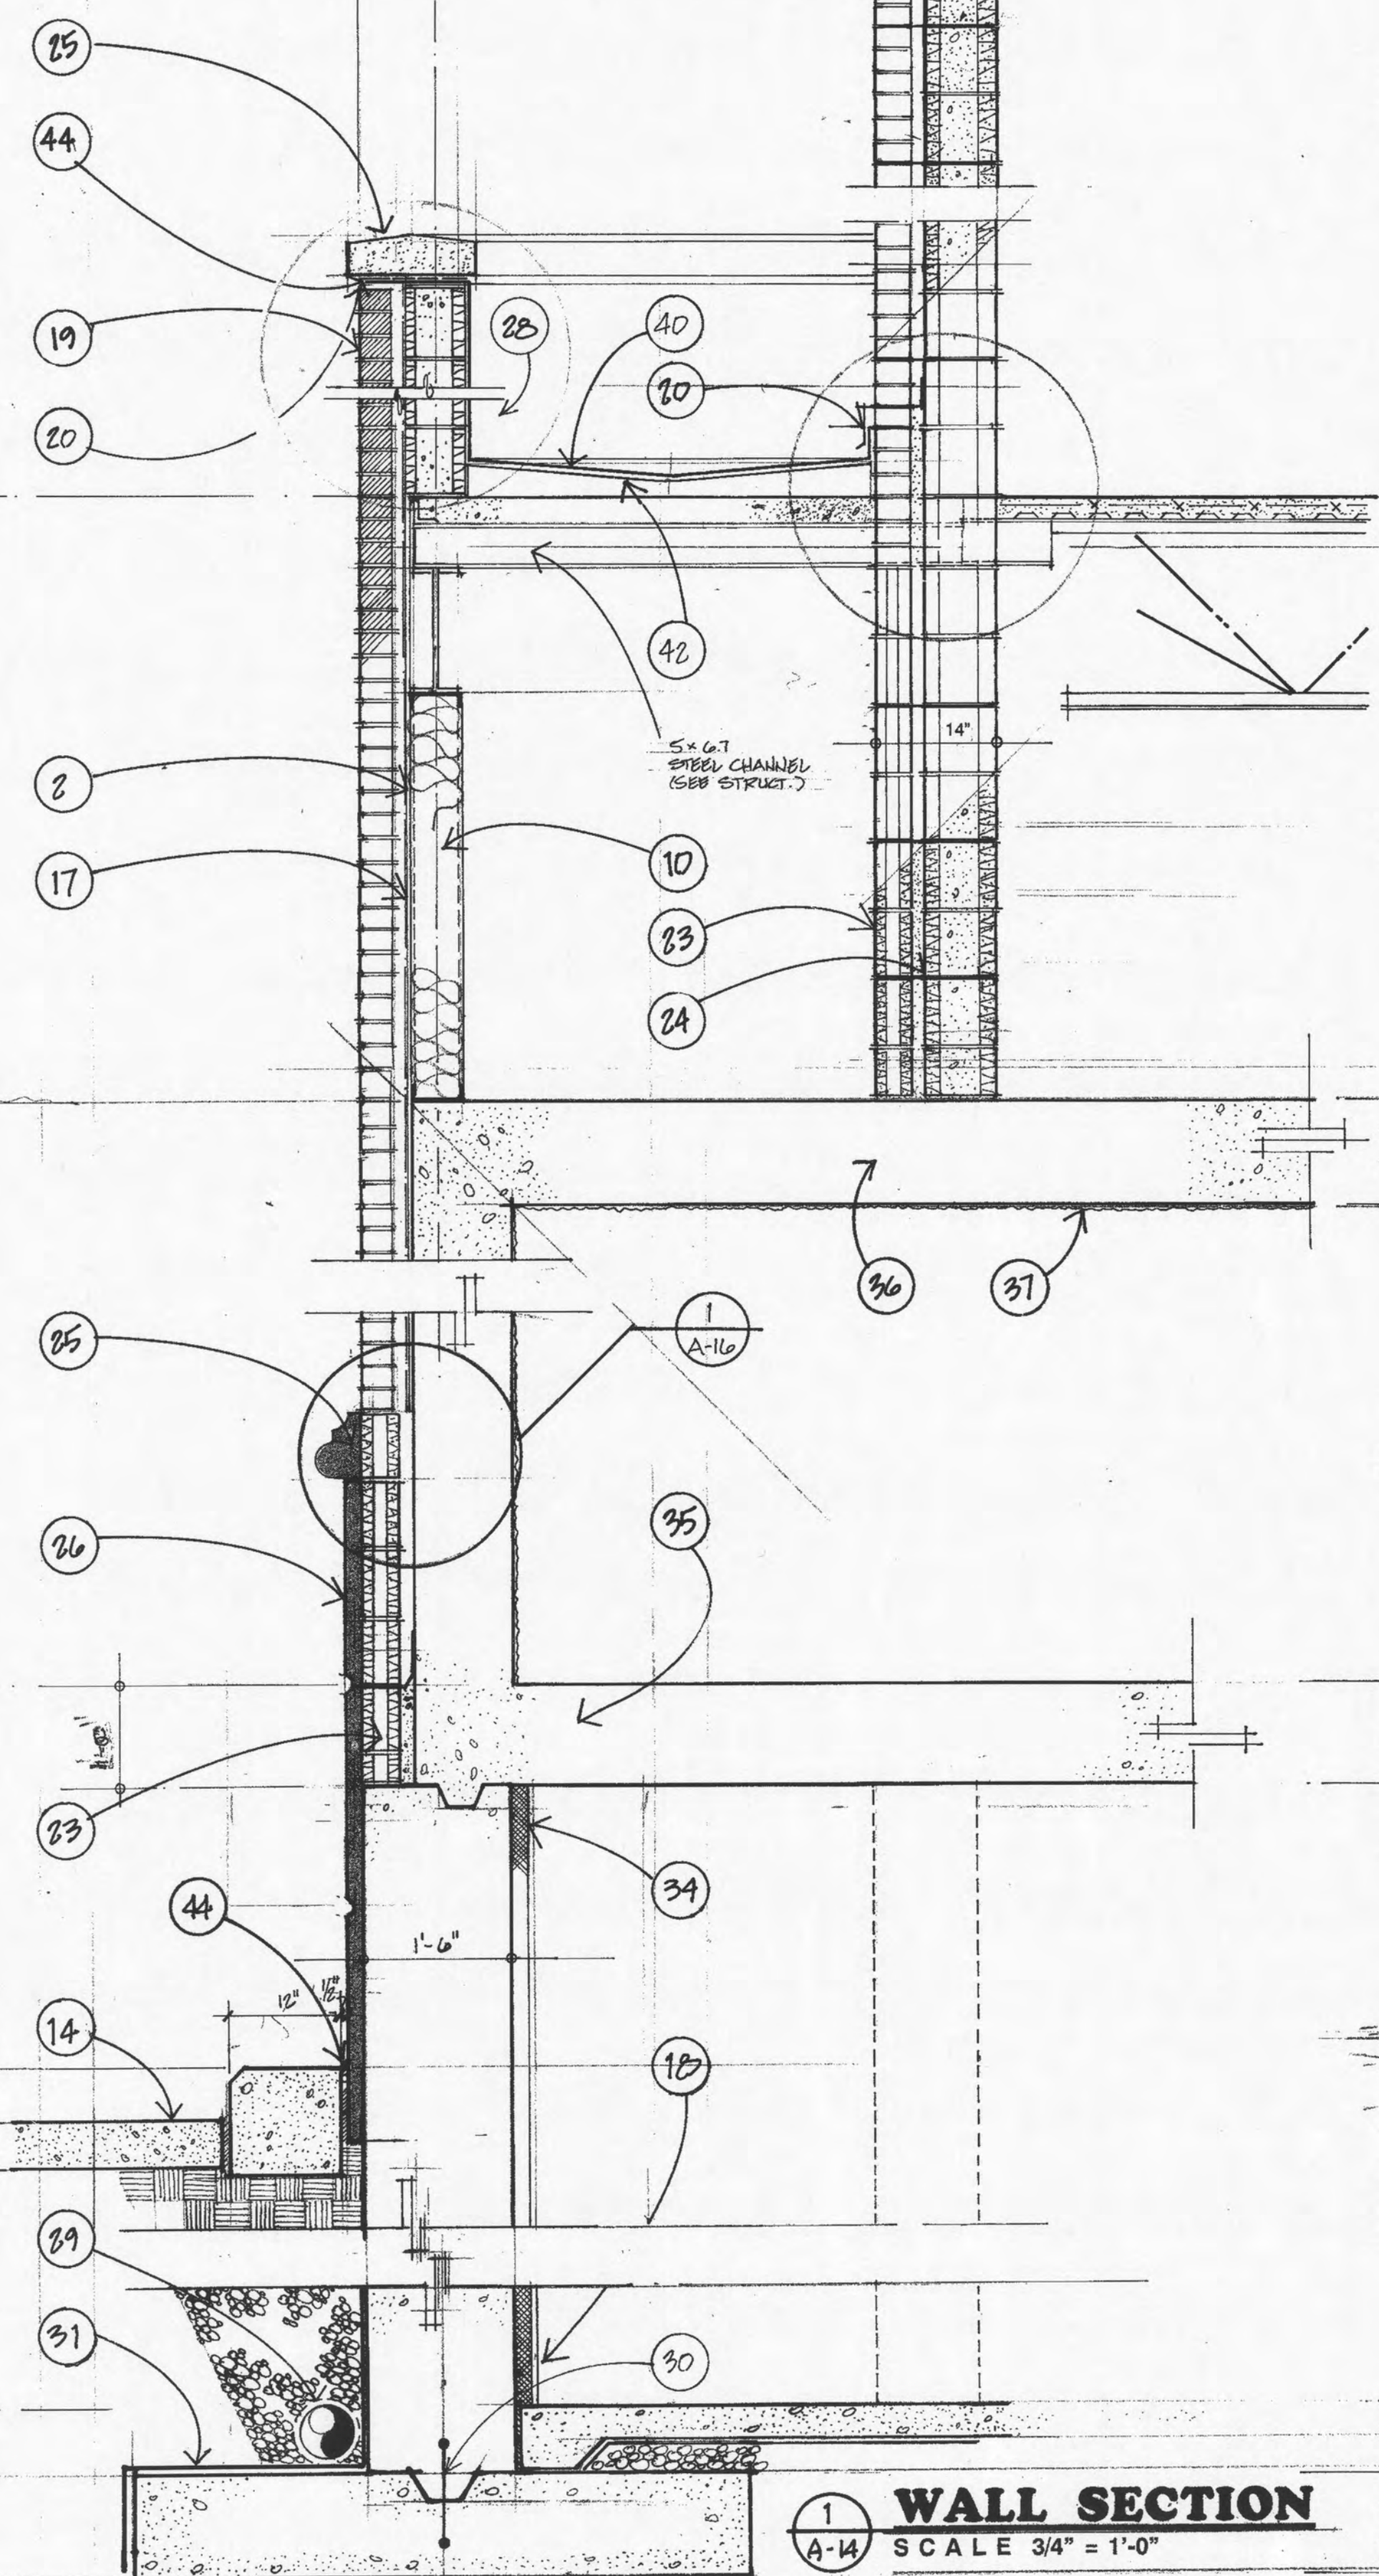

1 WALL SECTION
A-14 SCALE 3/4" = 1'-0"

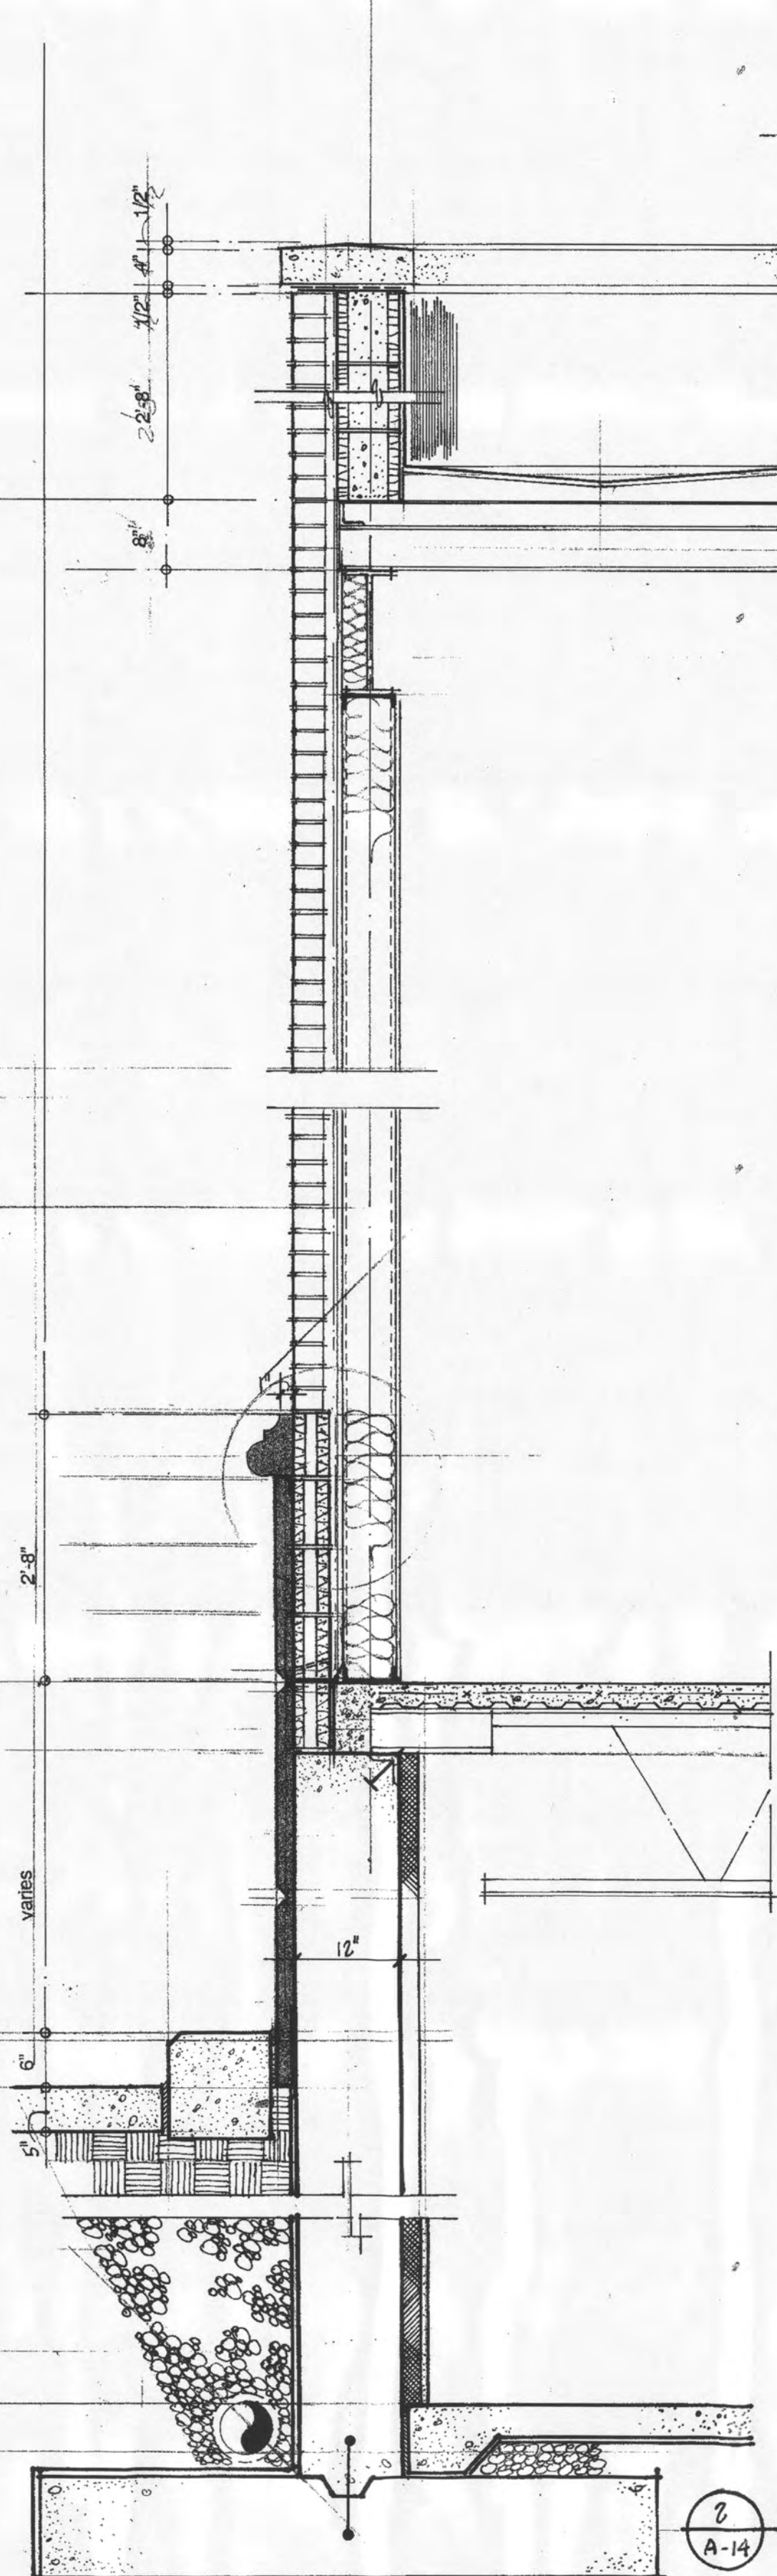

2 WALL SECTION
A-14 SCALE 3/4" = 1'-0"

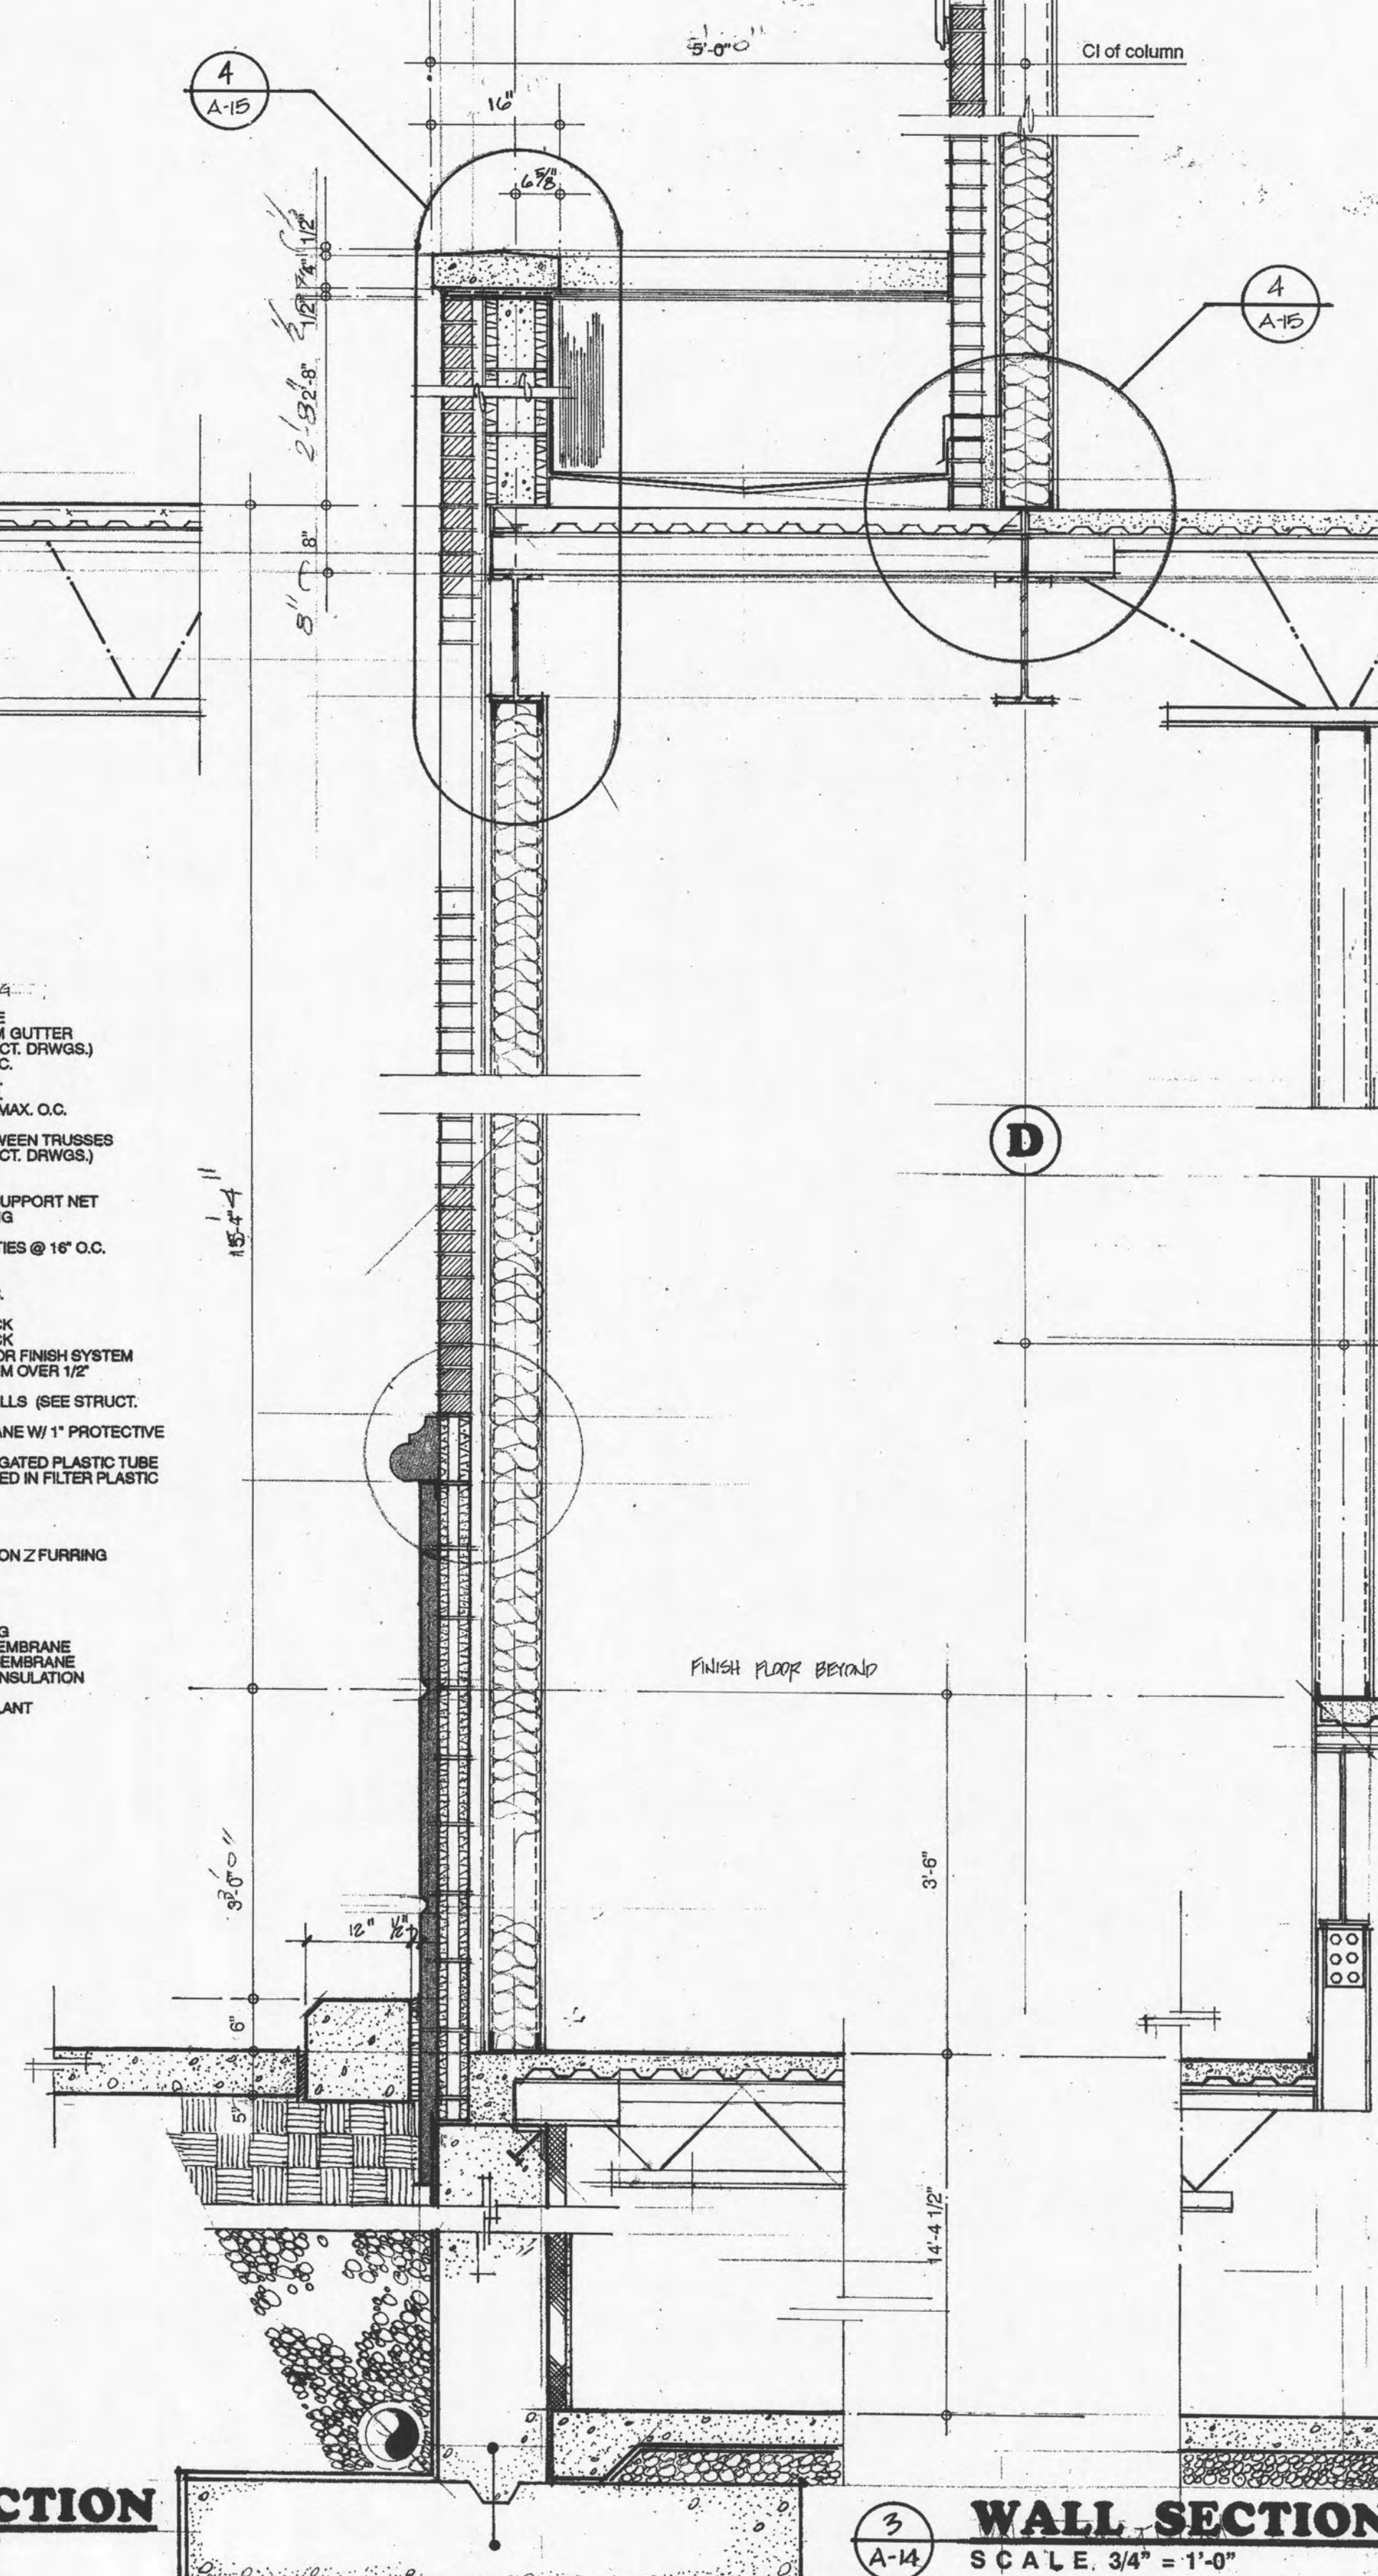

3 WALL SECTION
A-14 SCALE 3/4" = 1'-0"

LEGEND

1. ASPHALT SHINGLES
2. FELT PAPER
3. 1 1/2" DEEP METAL DECK
4. PREFINISHED ALUMINUM GUTTER
5. STEEL BEAM (SEE STRUCT. DWGS.)
6. 4" MTL. STUDS @ 5'-0" O.C.
7. 4" MTL. STUDS @ 16" O.C.
8. 6" MTL. STUDS @ 16" O.C.
9. STEEL TRUSSES @ 5'-0" MAX. O.C.
10. (SEE STRUCT. DWGS.)
11. C-JOINT BLOCKING BETWEEN TRUSSES
12. STEEL JOIST (SEE STRUCT. DWGS.)
13. CONCRETE SLAB
14. 6" BATT INSULATION
15. 9" BATT INSULATION W/ SUPPORT NET
16. 1/2" EXTERIOR SHEATHING
17. 1/2" INTERIOR GWS
18. BRICK VENEER W/ MTL. TIES @ 16" O.C.
19. (SEE STRUCT. DWGS.)
20. THRU-WALL FLASHING
21. WEEP HOLES @ 4'-0" O.C.
22. GROUT SOLID
23. 4" NOMINAL CONC. BLOCK
24. 8" NOMINAL CONC. BLOCK
25. SPECIAL SHAPE EXTERIOR FINISH SYSTEM
26. EXTERIOR FINISH SYSTEM OVER 1/2"
27. RIGID INSULATION
28. CONC. FOUNDATION WALLS (SEE STRUCT. DWGS.)
29. WATER-PROOF MEMBRANE W/ 1" PROTECTIVE BOARD
30. 6" PERFORATED CORRUGATED PLASTIC TUBE
31. FOOTING DRAIN WRAPPED IN FILTER PLASTIC
32. WATER STOP
33. VAPOR BARRIER
34. 4" GRAVEL
35. #4 STONE
36. 1 1/2" RIGID INSULATION ON Z FURRING
37. 12" VULT WALL
38. 12" VULT CEILING
39. SPRAYTEXTURE PAINT
40. 2"x2"x1/8" CONT. TUBE
41. PRECAST STONE COPING
42. SINGLE-PLY ROOFING MEMBRANE
43. SINGLE-PLY FLASHING MEMBRANE
44. TAPERED RIGID ROOF INSULATION
45. 12" CONCRETE CURB
46. BACK-UP ROD AND SEALANT

343	343
DESIGNED BY	CHECKED BY
DATE	DATE

Concepts

design-build
design-build
design-build

• Consultants
• Designers
• Construction Managers

1407252.0050
Harris Design Group, LLC
350 Russell Road

RELEASED FOR CONSTRUCTION

This drawing and the designs herein are the property of Design/Build Concepts, Inc. The reproduction or use of these drawings for any purpose other than as intended is prohibited. Design/Build Concepts, Inc. writing is prohibited.

ROBERT H. SMITH
REGISTERED PROFESSIONAL ENGINEER
STATE OF TENNESSEE
No. 000000

WALL SECTIONS

A NEW MAIN OFFICE FACILITIES FOR:



Bank of Roane County
HARRISMAN, TENNESSEE

JUNE 10, 1992

A-14

of 28 sheets



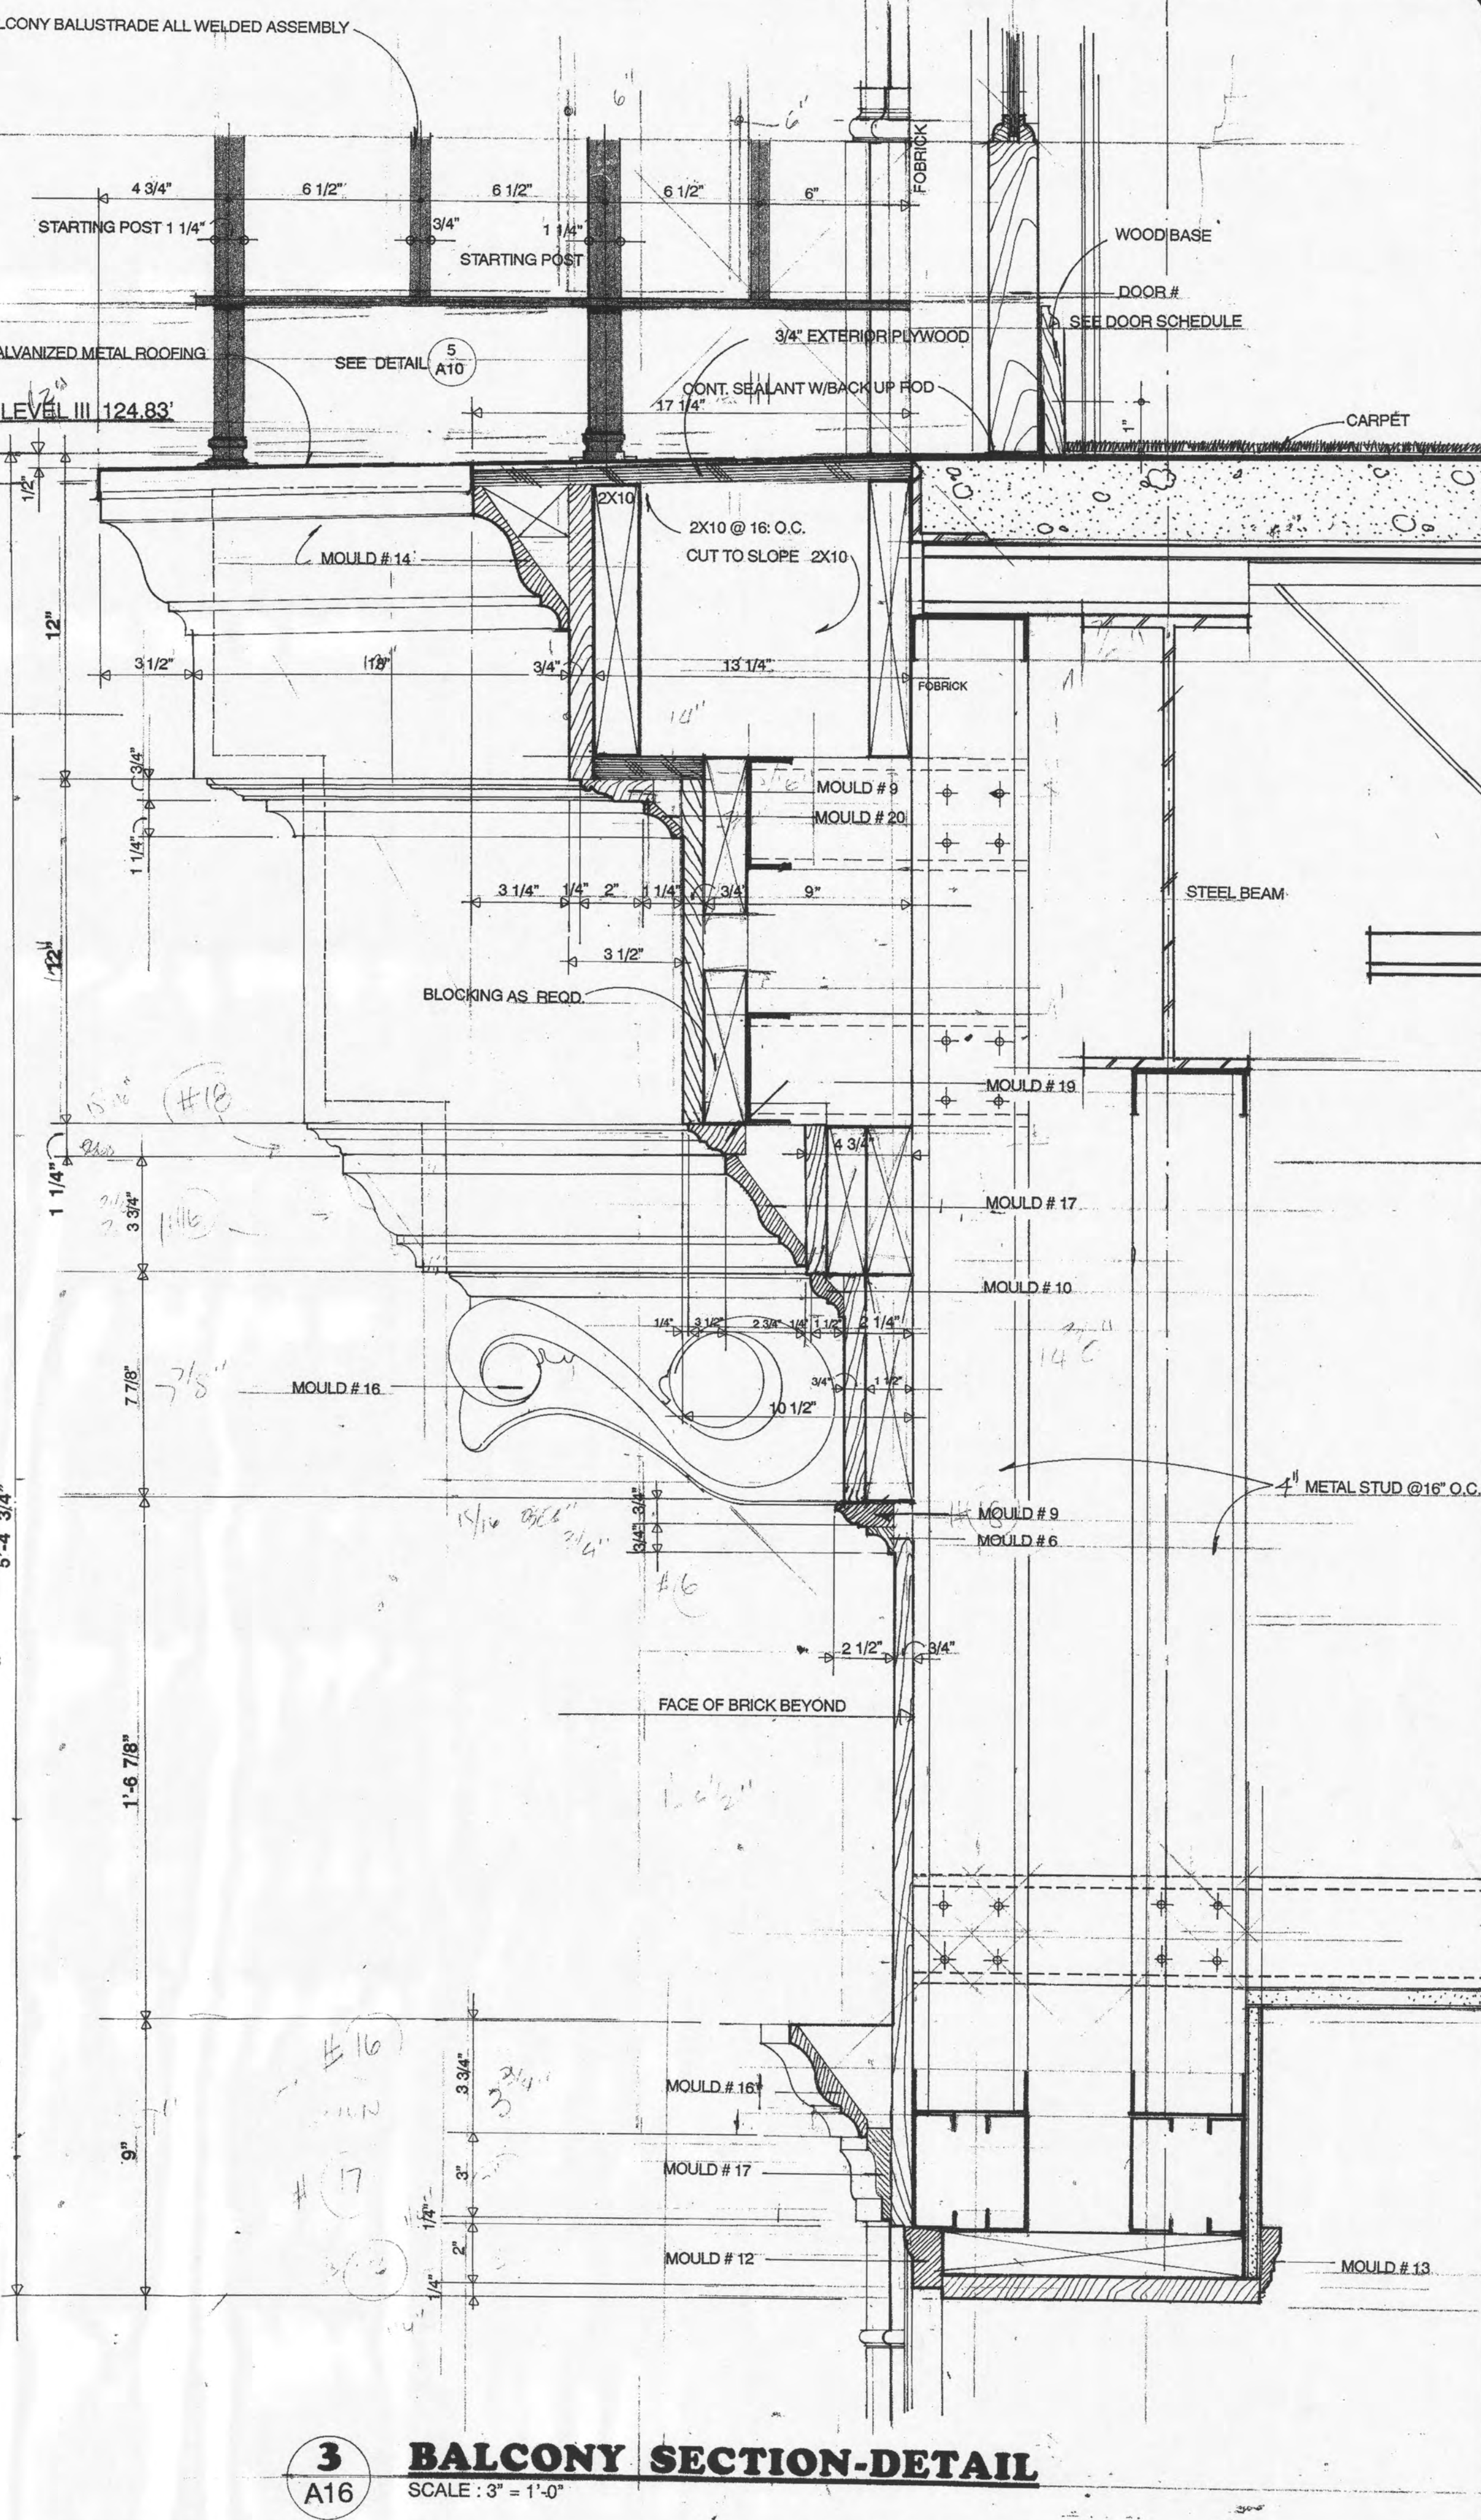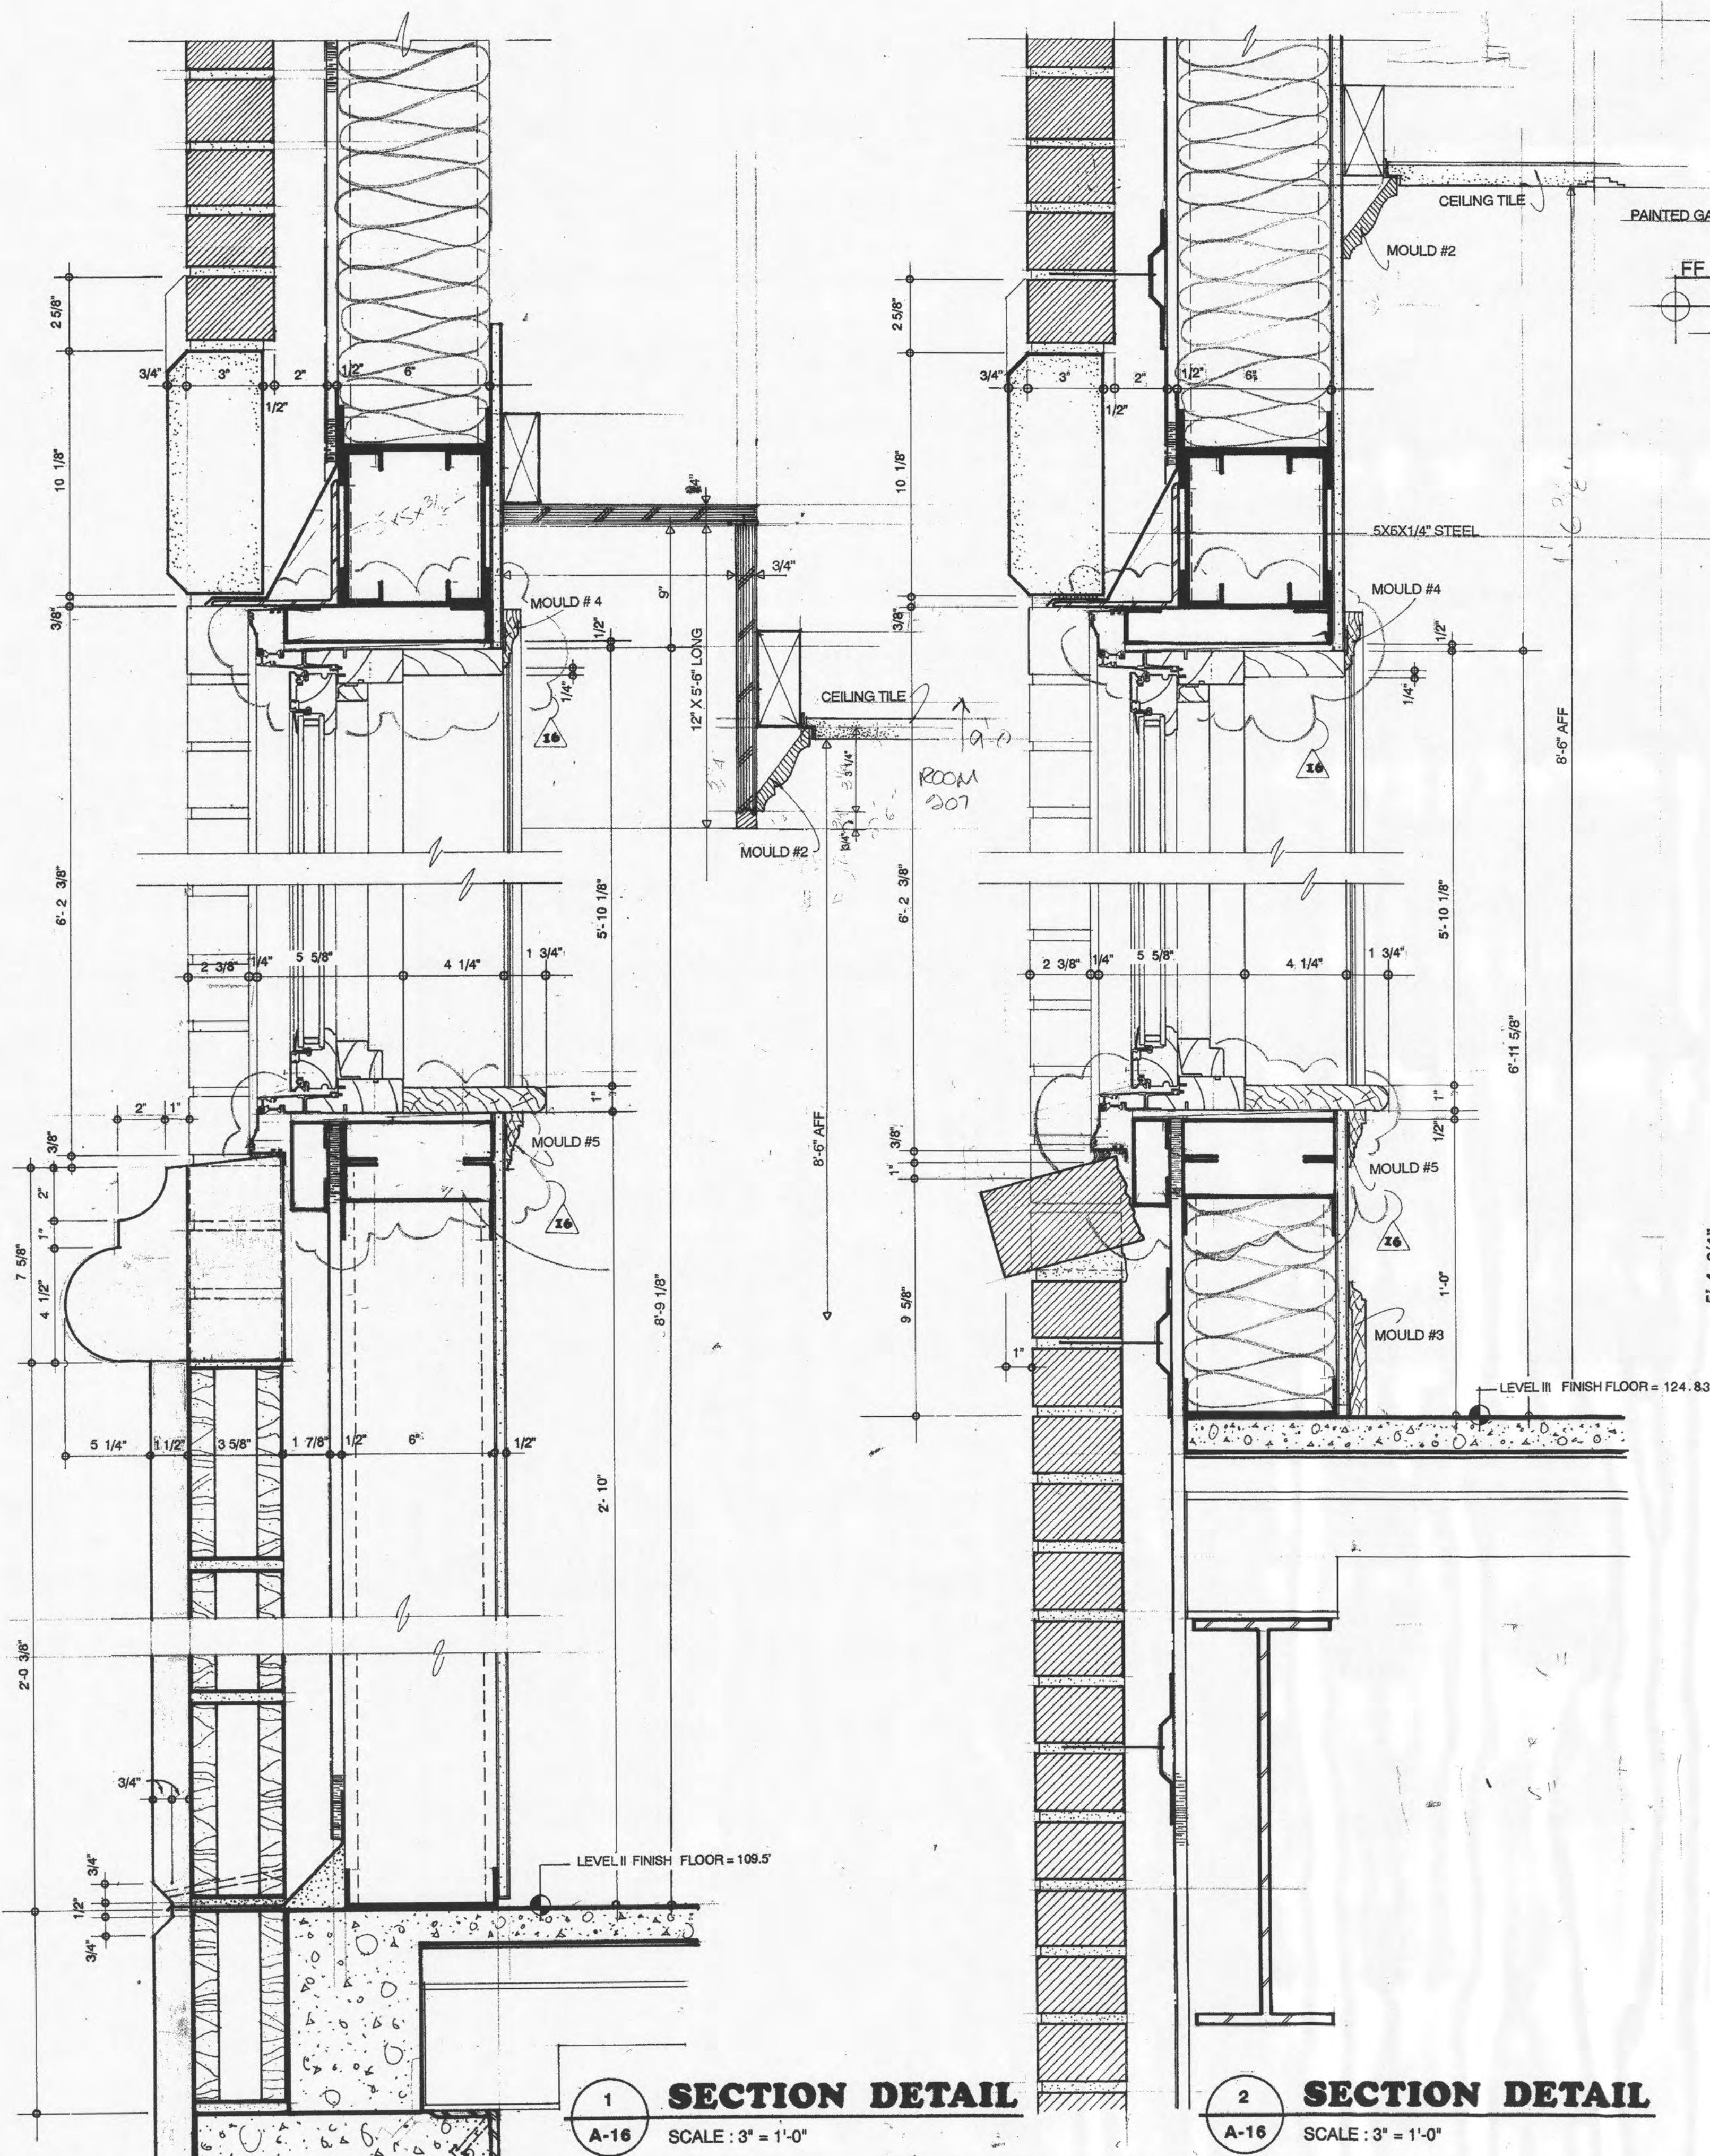

343	10/10	10/10	10/10
10/10	10/10	10/10	10/10
10/10	10/10	10/10	10/10
10/10	10/10	10/10	10/10

Concepts
design-build
design-build
design-build

CONSULTANTS
DESIGNERS
CONSTRUCTION MANAGERS

1991/255/080

RELEASED FOR CONSTRUCTION

THIS DRAWING AND THE DESIGN INFORMATION CONTAINED HEREIN ARE THE PROPERTY OF DESIGN-BUILD CONCEPTS, INC. AND ARE NOT TO BE REPRODUCED OR TRANSMITTED IN ANY FORM OR BY ANY MEANS, ELECTRONIC OR MECHANICAL, INCLUDING PHOTOCOPYING, RECORDING, OR BY ANY INFORMATION STORAGE AND RETRIEVAL SYSTEM, WITHOUT THE WRITTEN PERMISSION OF DESIGN-BUILD CONCEPTS, INC.

SECTION DETAILS


A NEW MAIN OFFICE FACILITIES FOR:

Bank of Roane County
HARRIMAN, TENNESSEE

JUNE 10, 1992

A-16

25 SHEETS

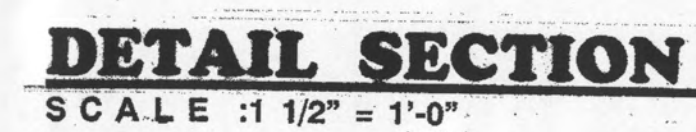



LEGEND

CONSTRUCTION TYPE : IV, SPRINKLERED, UNPROTECTED
OCCUPANCY TYPE : BUSINESS
STORIES: 4
BUILDING AREA : LEVEL I = 8267 SF
SEISMIC ZONE 2

ARCHITECTURAL

- A-1 SITE PLAN AND DETAILS
- A-2 SITE GRADING & DRAINAGE
- A-3 FLOOR PLAN - LEVEL I
- A-4 FLOOR PLAN - LEVEL II
- A-5 FLOOR PLAN - LEVEL III / ATTIC SPACE & ROOF PLAN
- A-6 LARGE SCALE PLAN DETAILS
- A-7 FRONT ELEVATION & DETAILS
- A-8 SIDE ELEVATIONS & DETAILS
- A-9 REAR ELEVATION & DETAILS
- A-10 BALCONY / HANDRAIL DETAILS
- A-11 BUILDING SECTION
- A-12 BUILDING SECTION
- A-13 WALL SECTIONS / DETAILS
- A-14 WALL SECTIONS
- A-15 SECTION DETAILS

SECTION DETAILS

- A-16 SECTION DETAILS
- A-17 WINDOW ELEVATIONS / SECTION
- A-18 DRIVE-UP WINDOW / SECTION DETAILS
- A-19 LARGE SCALE STAIR PLANS
- A-20 STAIR SECTIONS / DETAILS
- A-21 NOT USED
- A-22 DOOR SCHEDULE / DETAILS
- A-23 HEAD / JAMB / SILL DETAILS / MILLWORK DETAILS
- A-24 MILLWORK / PLAN DETAILS
- A-25 REFLECTED CEILING PLAN - LEVEL I / DETAILS
- A-26 REFLECTED CEILING PLAN - LEVEL II / DETAILS
- A-27 REFLECTED CEILING PLAN - LEVEL III / DETAILS
- A-28

STRUCTURAL

- S-1 SLAB AND FOUNDATION PLAN - LEVEL I
- S-2 FLOOR FRAMING PLAN - LEVEL II
- S-3 FLOOR FRAMING PLAN - LEVEL III
- S-4 ROOF FRAMING PLAN
- S-5 SECTIONS AND DETAILS
- S-6 SECTIONS AND DETAILS
- S-7 STAIR REVISIONS

PLUMBING

- P-1 LEVEL I / II PLUMBING FLOOR PLANS & RISER DIAGRAMS
- P-2 LEVEL III PLUMBING PLAN / SCHEDULES & DETAILS

MECHANICAL

- AC-1 LEVEL I / II HVAC PLANS / MECHANICAL ROOM PART PLANS
- AC-2 LEVEL III HVAC PLAN / SCHEDULES & DETAILS

ELECTRICAL

- E-1 ELECTRICAL SITE PLAN
- E-2 SECURITY DIAGRAMS
- E-3 ELECTRICAL FLOOR PLAN / LIGHTING - LEVEL I
- E-4 ELECTRICAL FLOOR PLAN / LIGHTING - LEVEL II
- E-5 ELECTRICAL FLOOR PLAN / LIGHTING - LEVEL III
- E-6 ELECTRICAL FLOOR PLAN / POWER - LEVEL I

ELECTRICAL FLOOR PLAN / POWER - LEVEL II

- E-7 ELECTRICAL FLOOR PLAN / POWER - LEVEL II
- E-8 ELECTRICAL FLOOR PLAN / POWER - LEVEL III
- E-9 PANEL SCHEDULES

INTERIOR WORK

- IW-1 FLOOR PLAN - LEVEL I
- IW-2 FLOOR PLAN - LEVEL II
- IW-3 FLOOR PLAN - LEVEL III
- IW-4 TELLER COUNTER ELEVATIONS, PLANS & GENERAL NOTES
- IW-5 TELLER COUNTER ELEVATIONS, SECTIONS & DETAILS
- IW-6 TELLER COUNTER SECTIONS & DETAILS

TITLE SHEET

A NEW MAIN OFFICE FACILITY FOR:
Bank of Roane County
HARRISMAN, TENNESSEE

DATE: JUNE 10, 92
SHEET: 1

T-1
OF 1 SHEETS




Concepts
design-build
design-build
design-build


Consultants
Designers
Construction Managers

580 Russell Road
Roane County, TN 37642
(615) 256-1980

NO. 343	DATE	BY
September 9, 92	16 RV	
DESIGNED	CHECKED	DATE

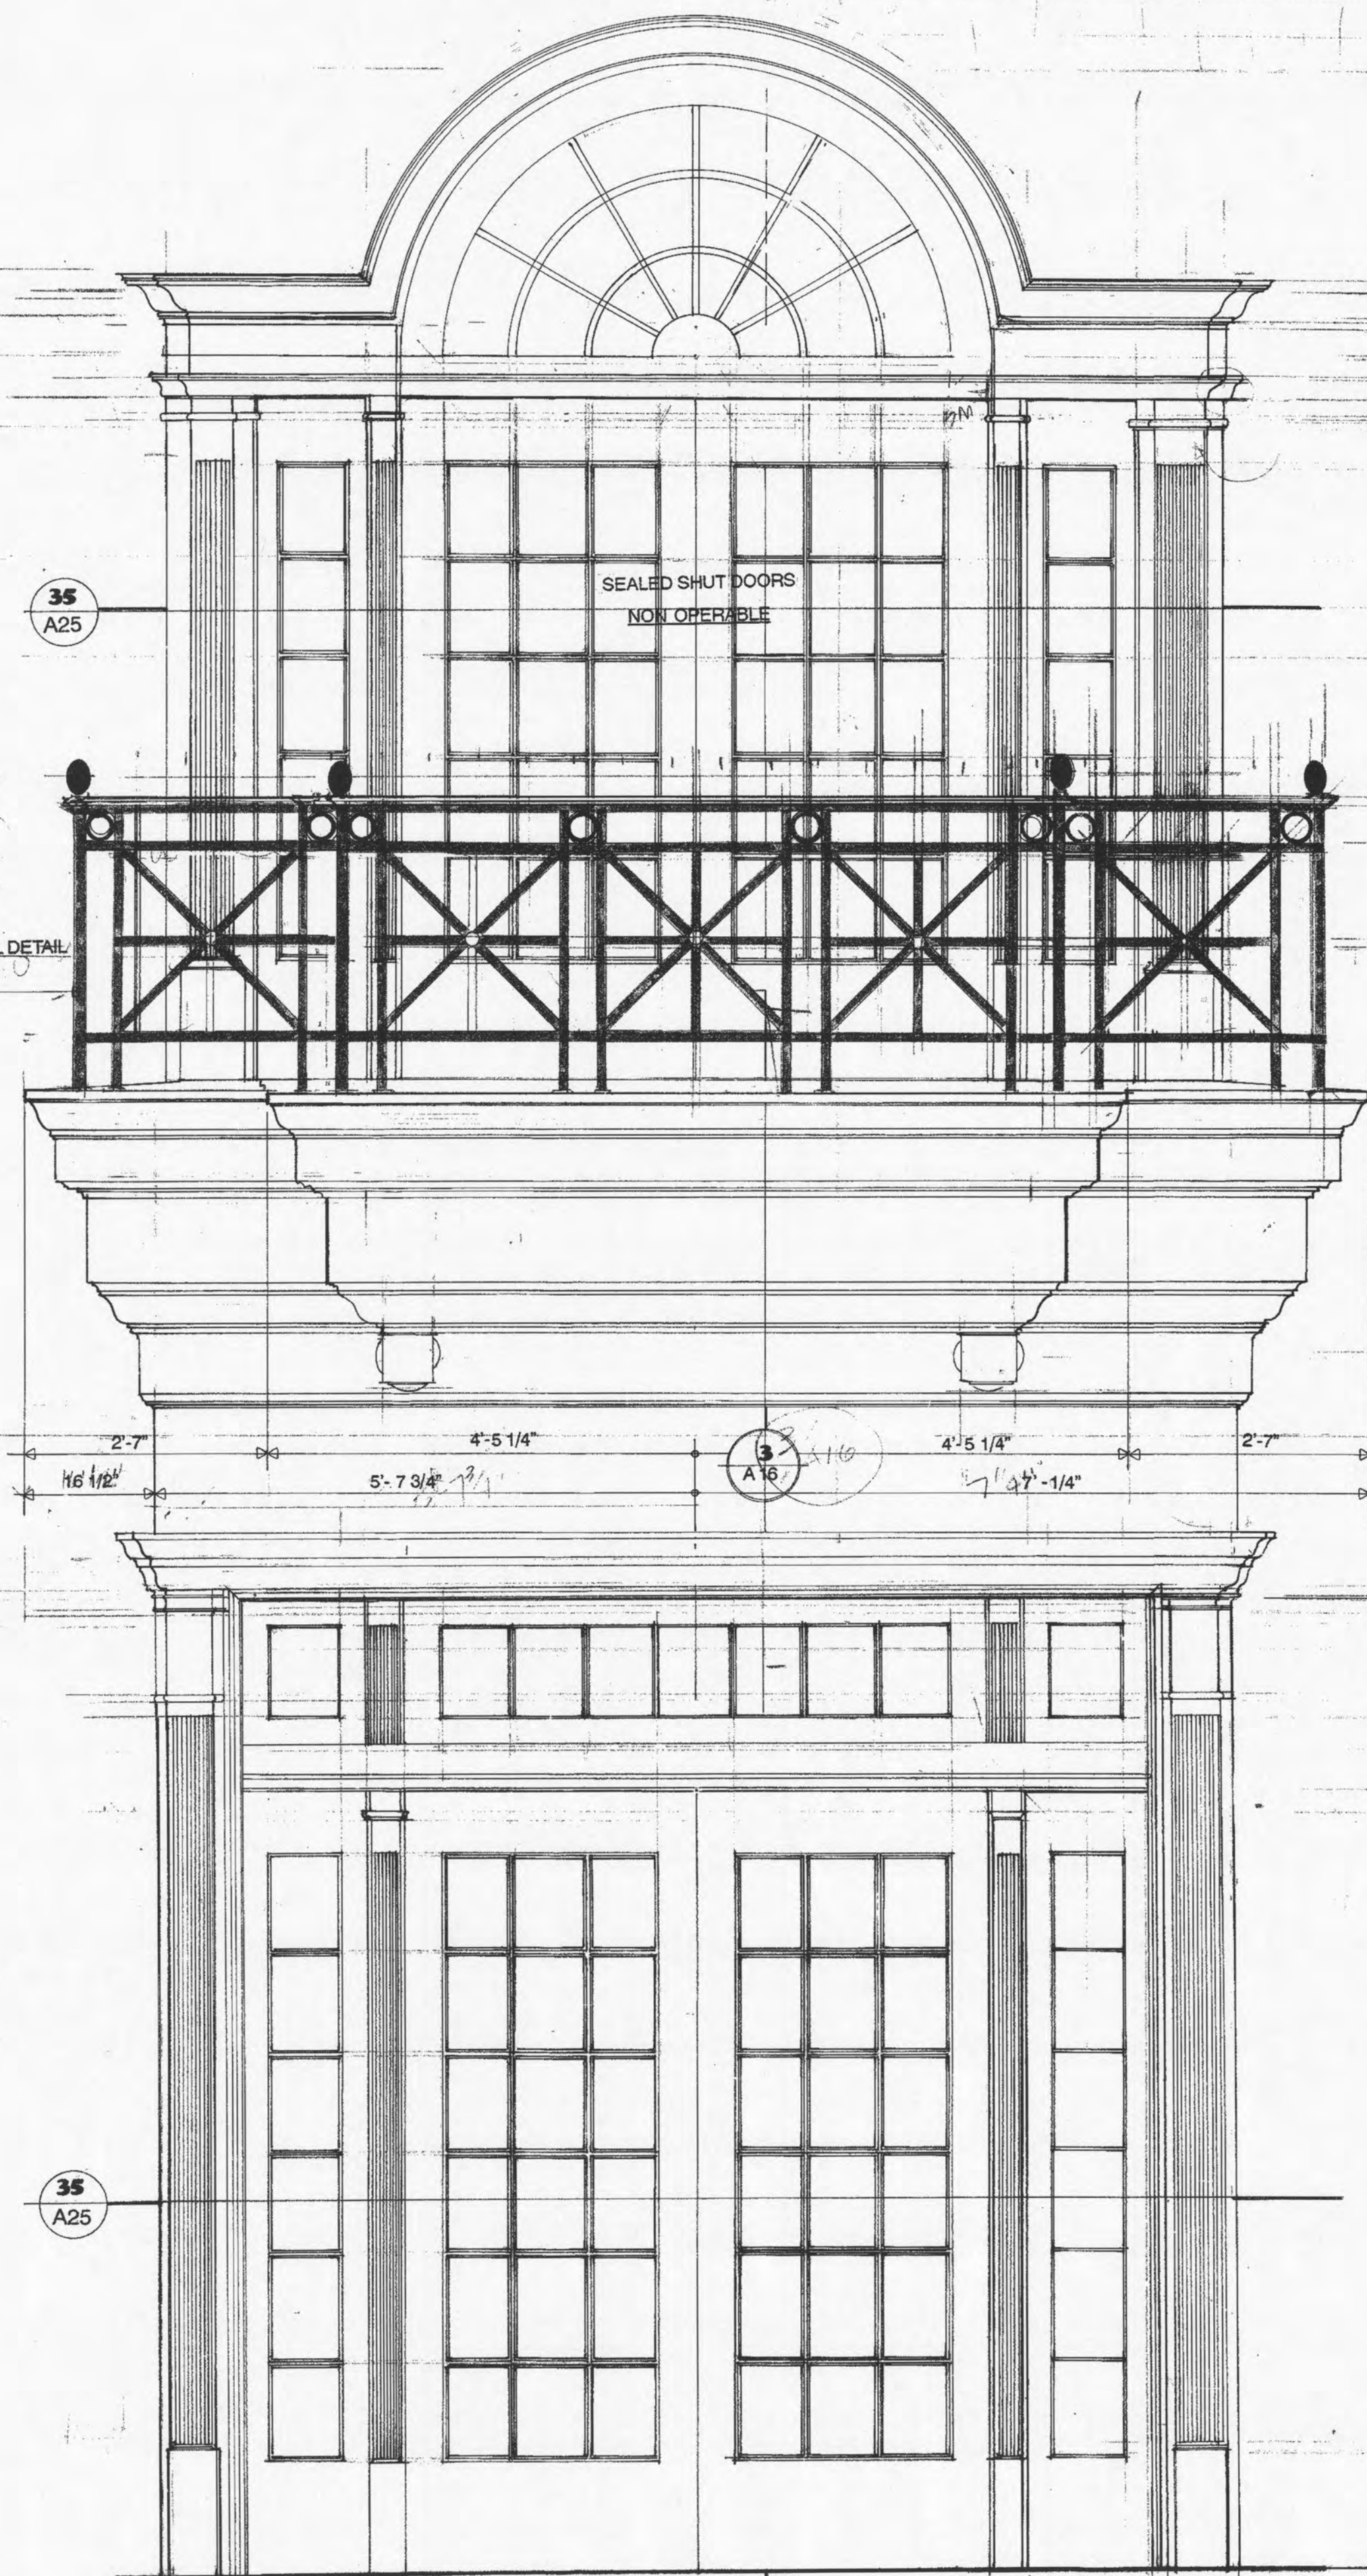


1 PORTICO ELEVATION
SCALE: 3/4" = 1'-0"

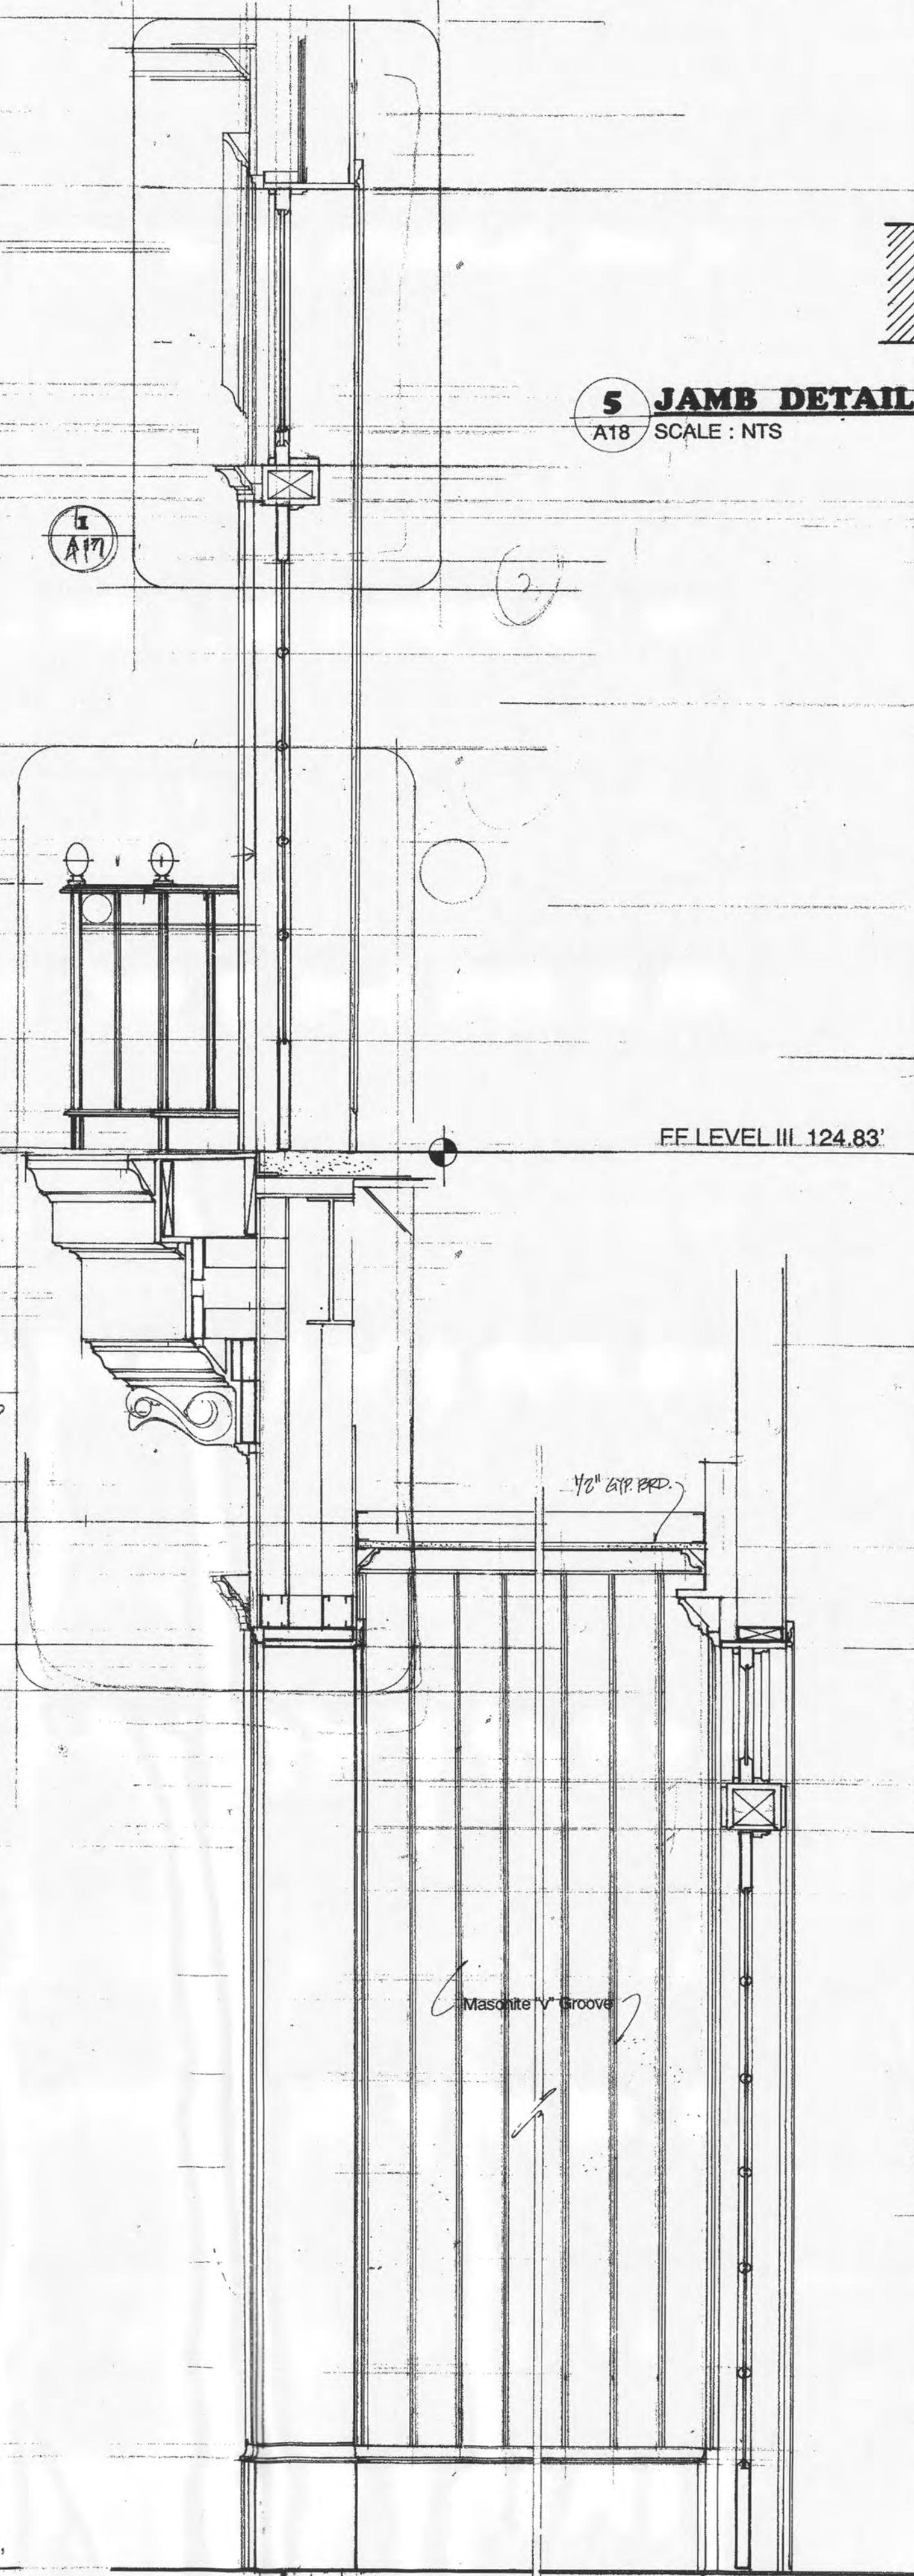

2 WALL SECTION A
SCALE: 3/4" = 1'-0"



3 WINDOW ELEVATION
SCALE: 3/4" = 1'-0" (LEVEL III)

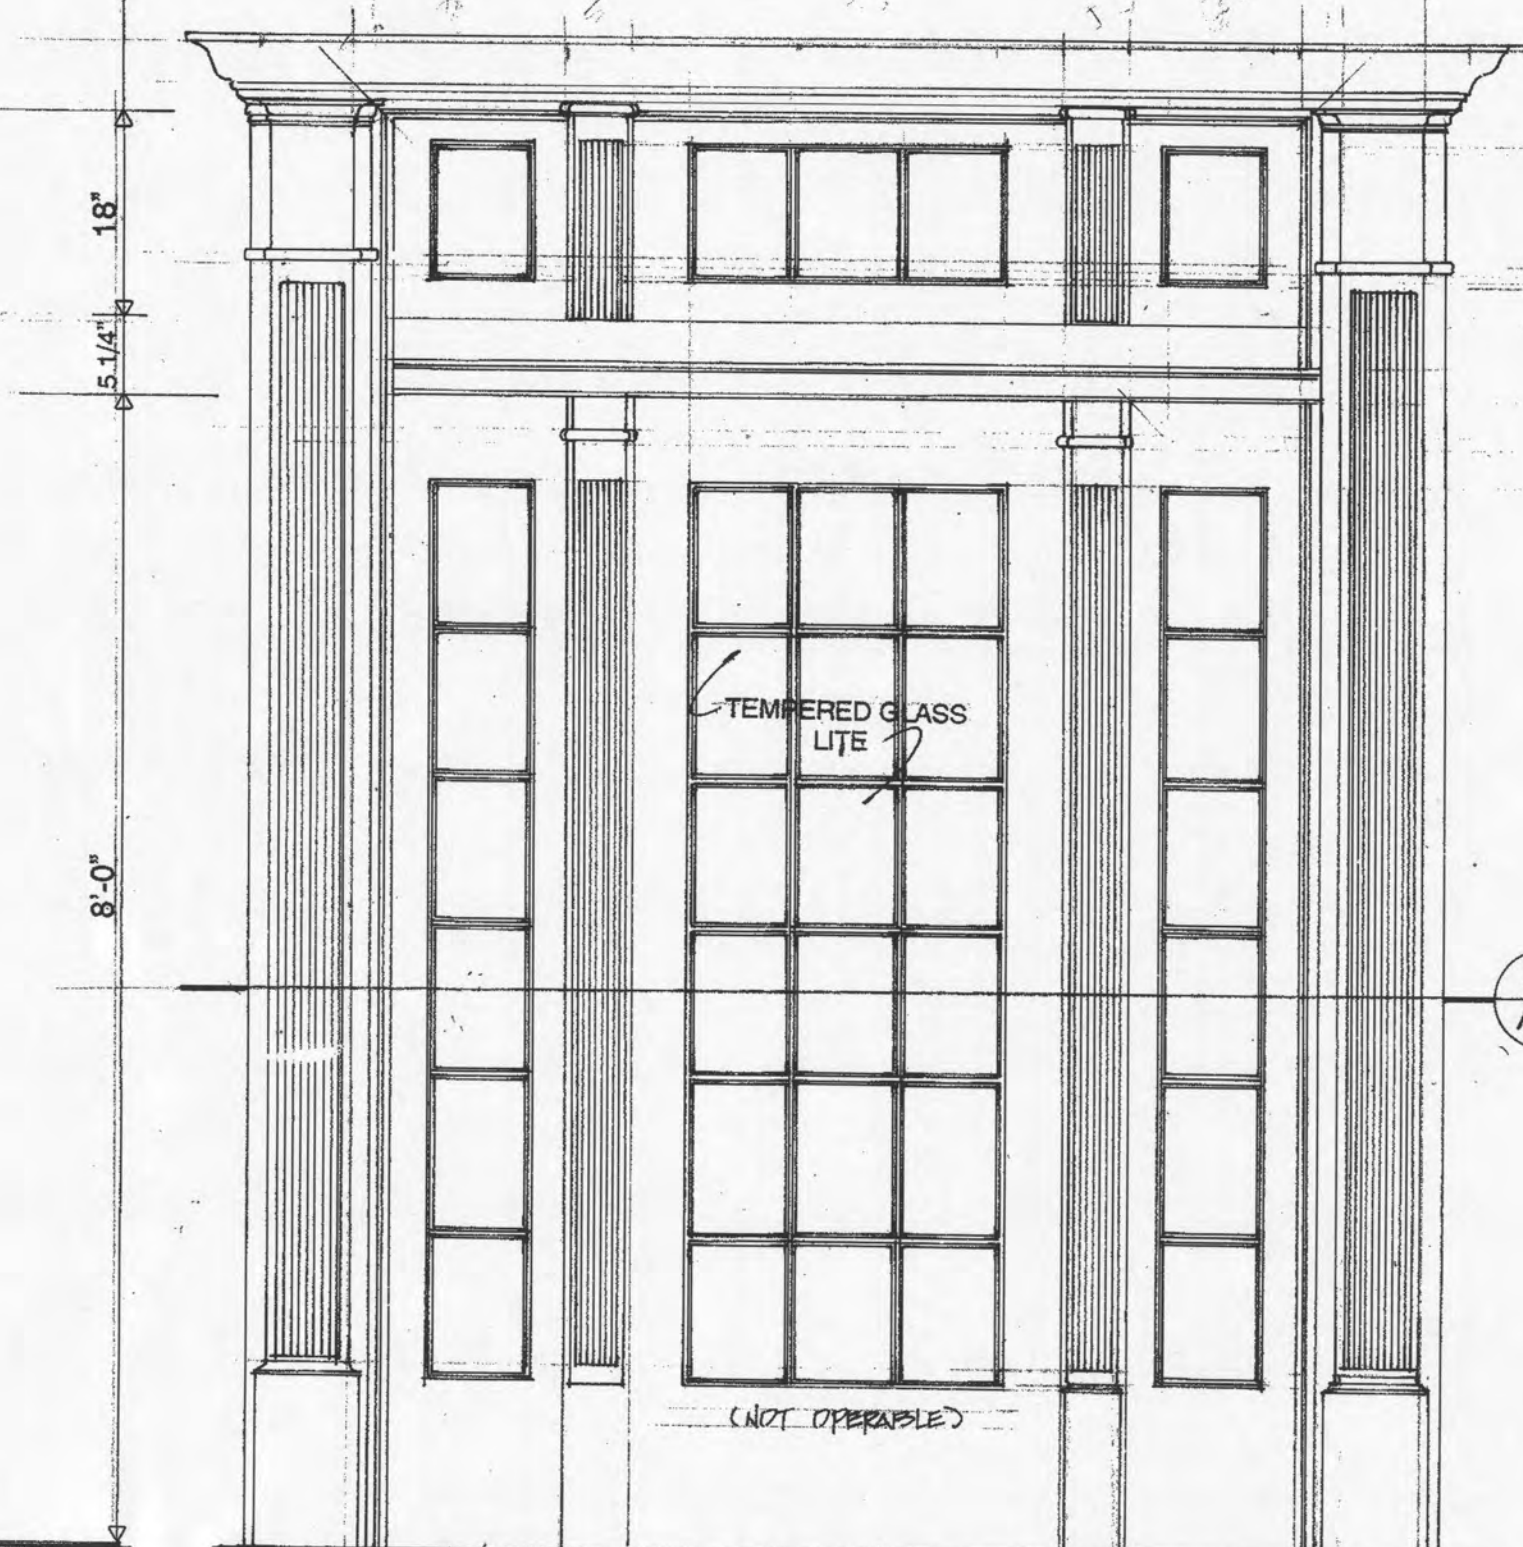

4 WINDOW ELEVATION
SCALE: 3/4" = 1'-0" (LEVEL II)

5 JAMB DETAIL
A18 SCALE: NTS

DATE	3/10
BY	343
CHECKED	CK
DESIGNED	CK
QUANTITY	1
REVISION	

Concepts
design-build
design-build
design-build
design-build

Consultants
Designers
Construction Managers

3500 Residual Road
Harrisburg, PA 17109

RELEASED FOR CONSTRUCTION

ROBERT R. SMITH
ARCHITECT
STATE OF TENNESSEE
1988


This drawing and the designs herein are the property of Robert R. Smith Architect. No part of this drawing may be reproduced or used in any form without the written permission of Robert R. Smith Architect.

SHEET DESCRIPTION: WINDOW ELEVATIONS / SECTION


A NEW MAIN OFFICE FACILITIES FOR:

Bank of Roane County
HARRIMAN, TENNESSEE


SHEET: A-18
JUNE 10, 1992

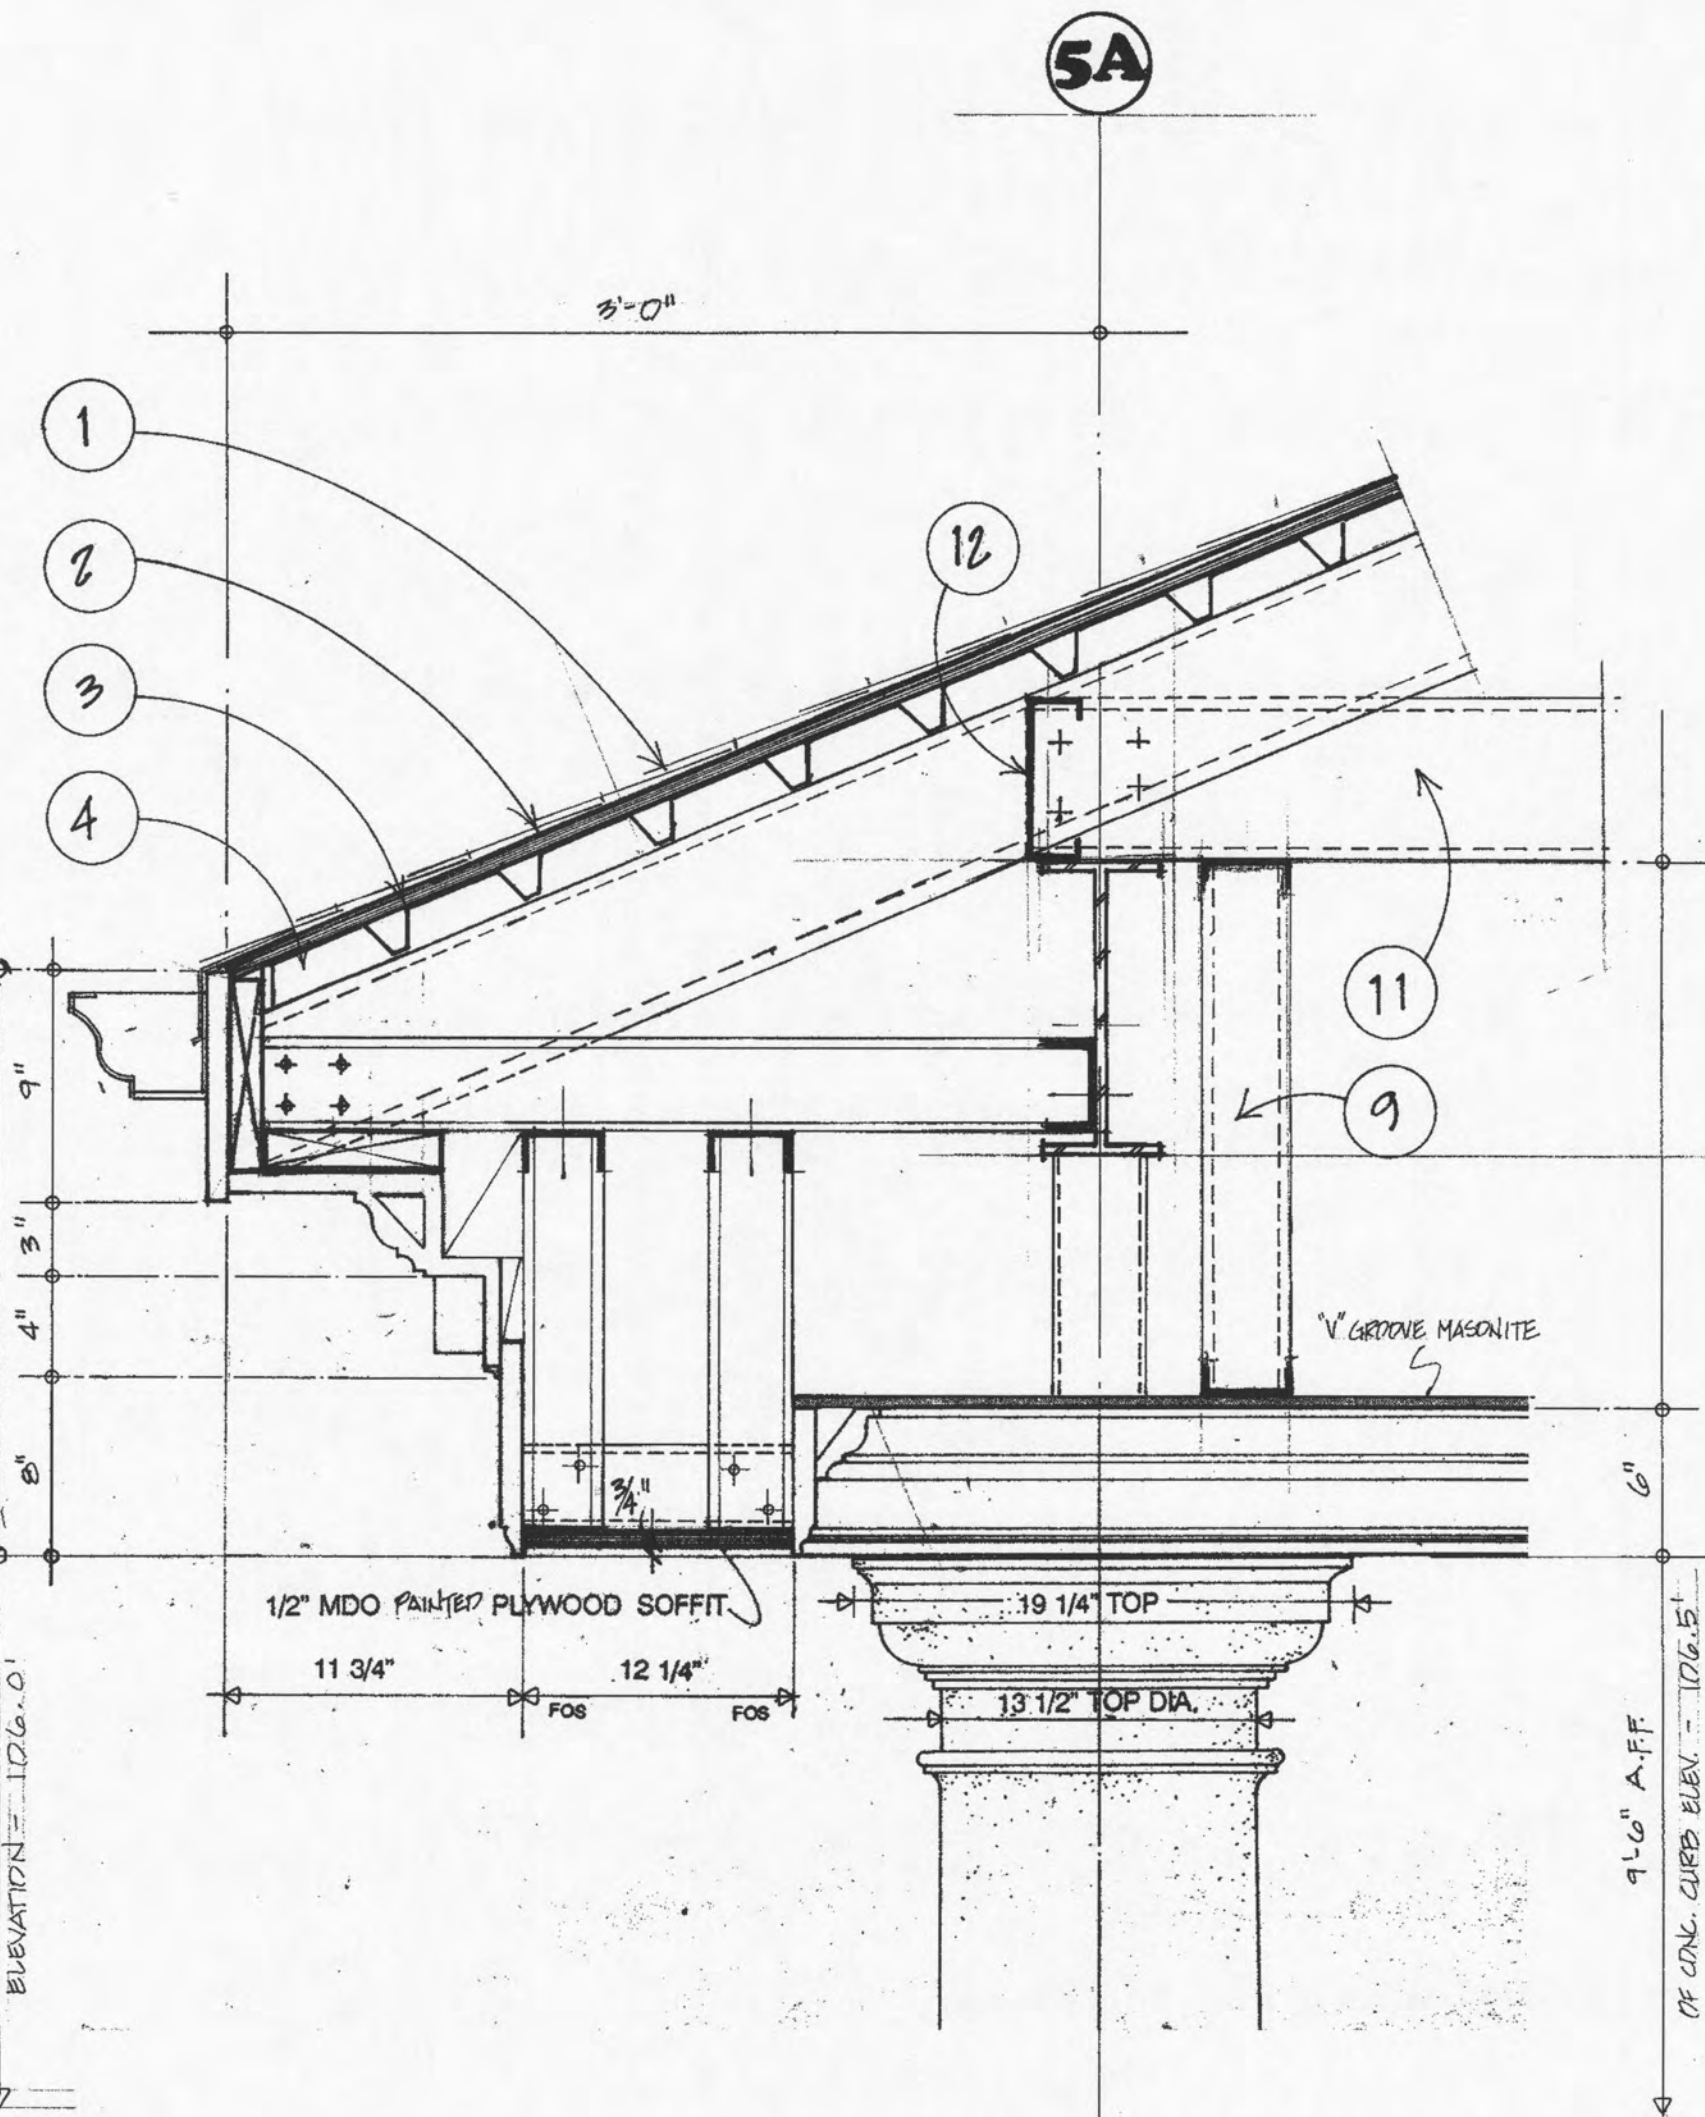

1 PARTIAL DRIVE-UP CANOPY
A-19 SCALE: 1 1/2" = 1'-0"

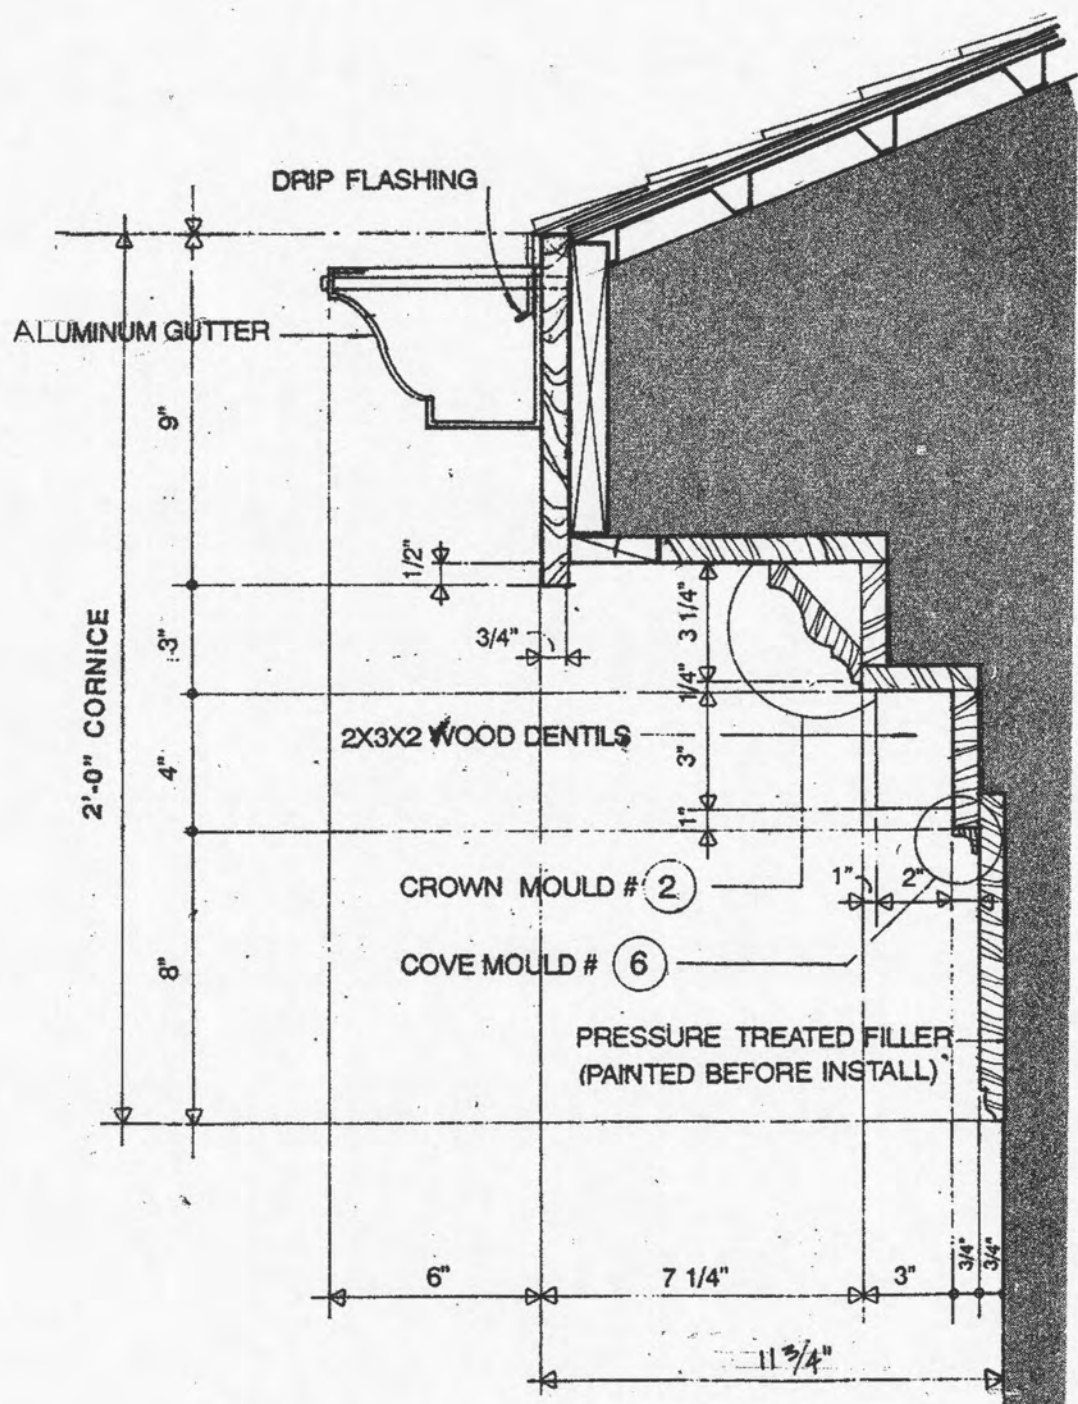


3 PARTIAL PORTICO SECTION
A-17 SCALE: N.T.S.




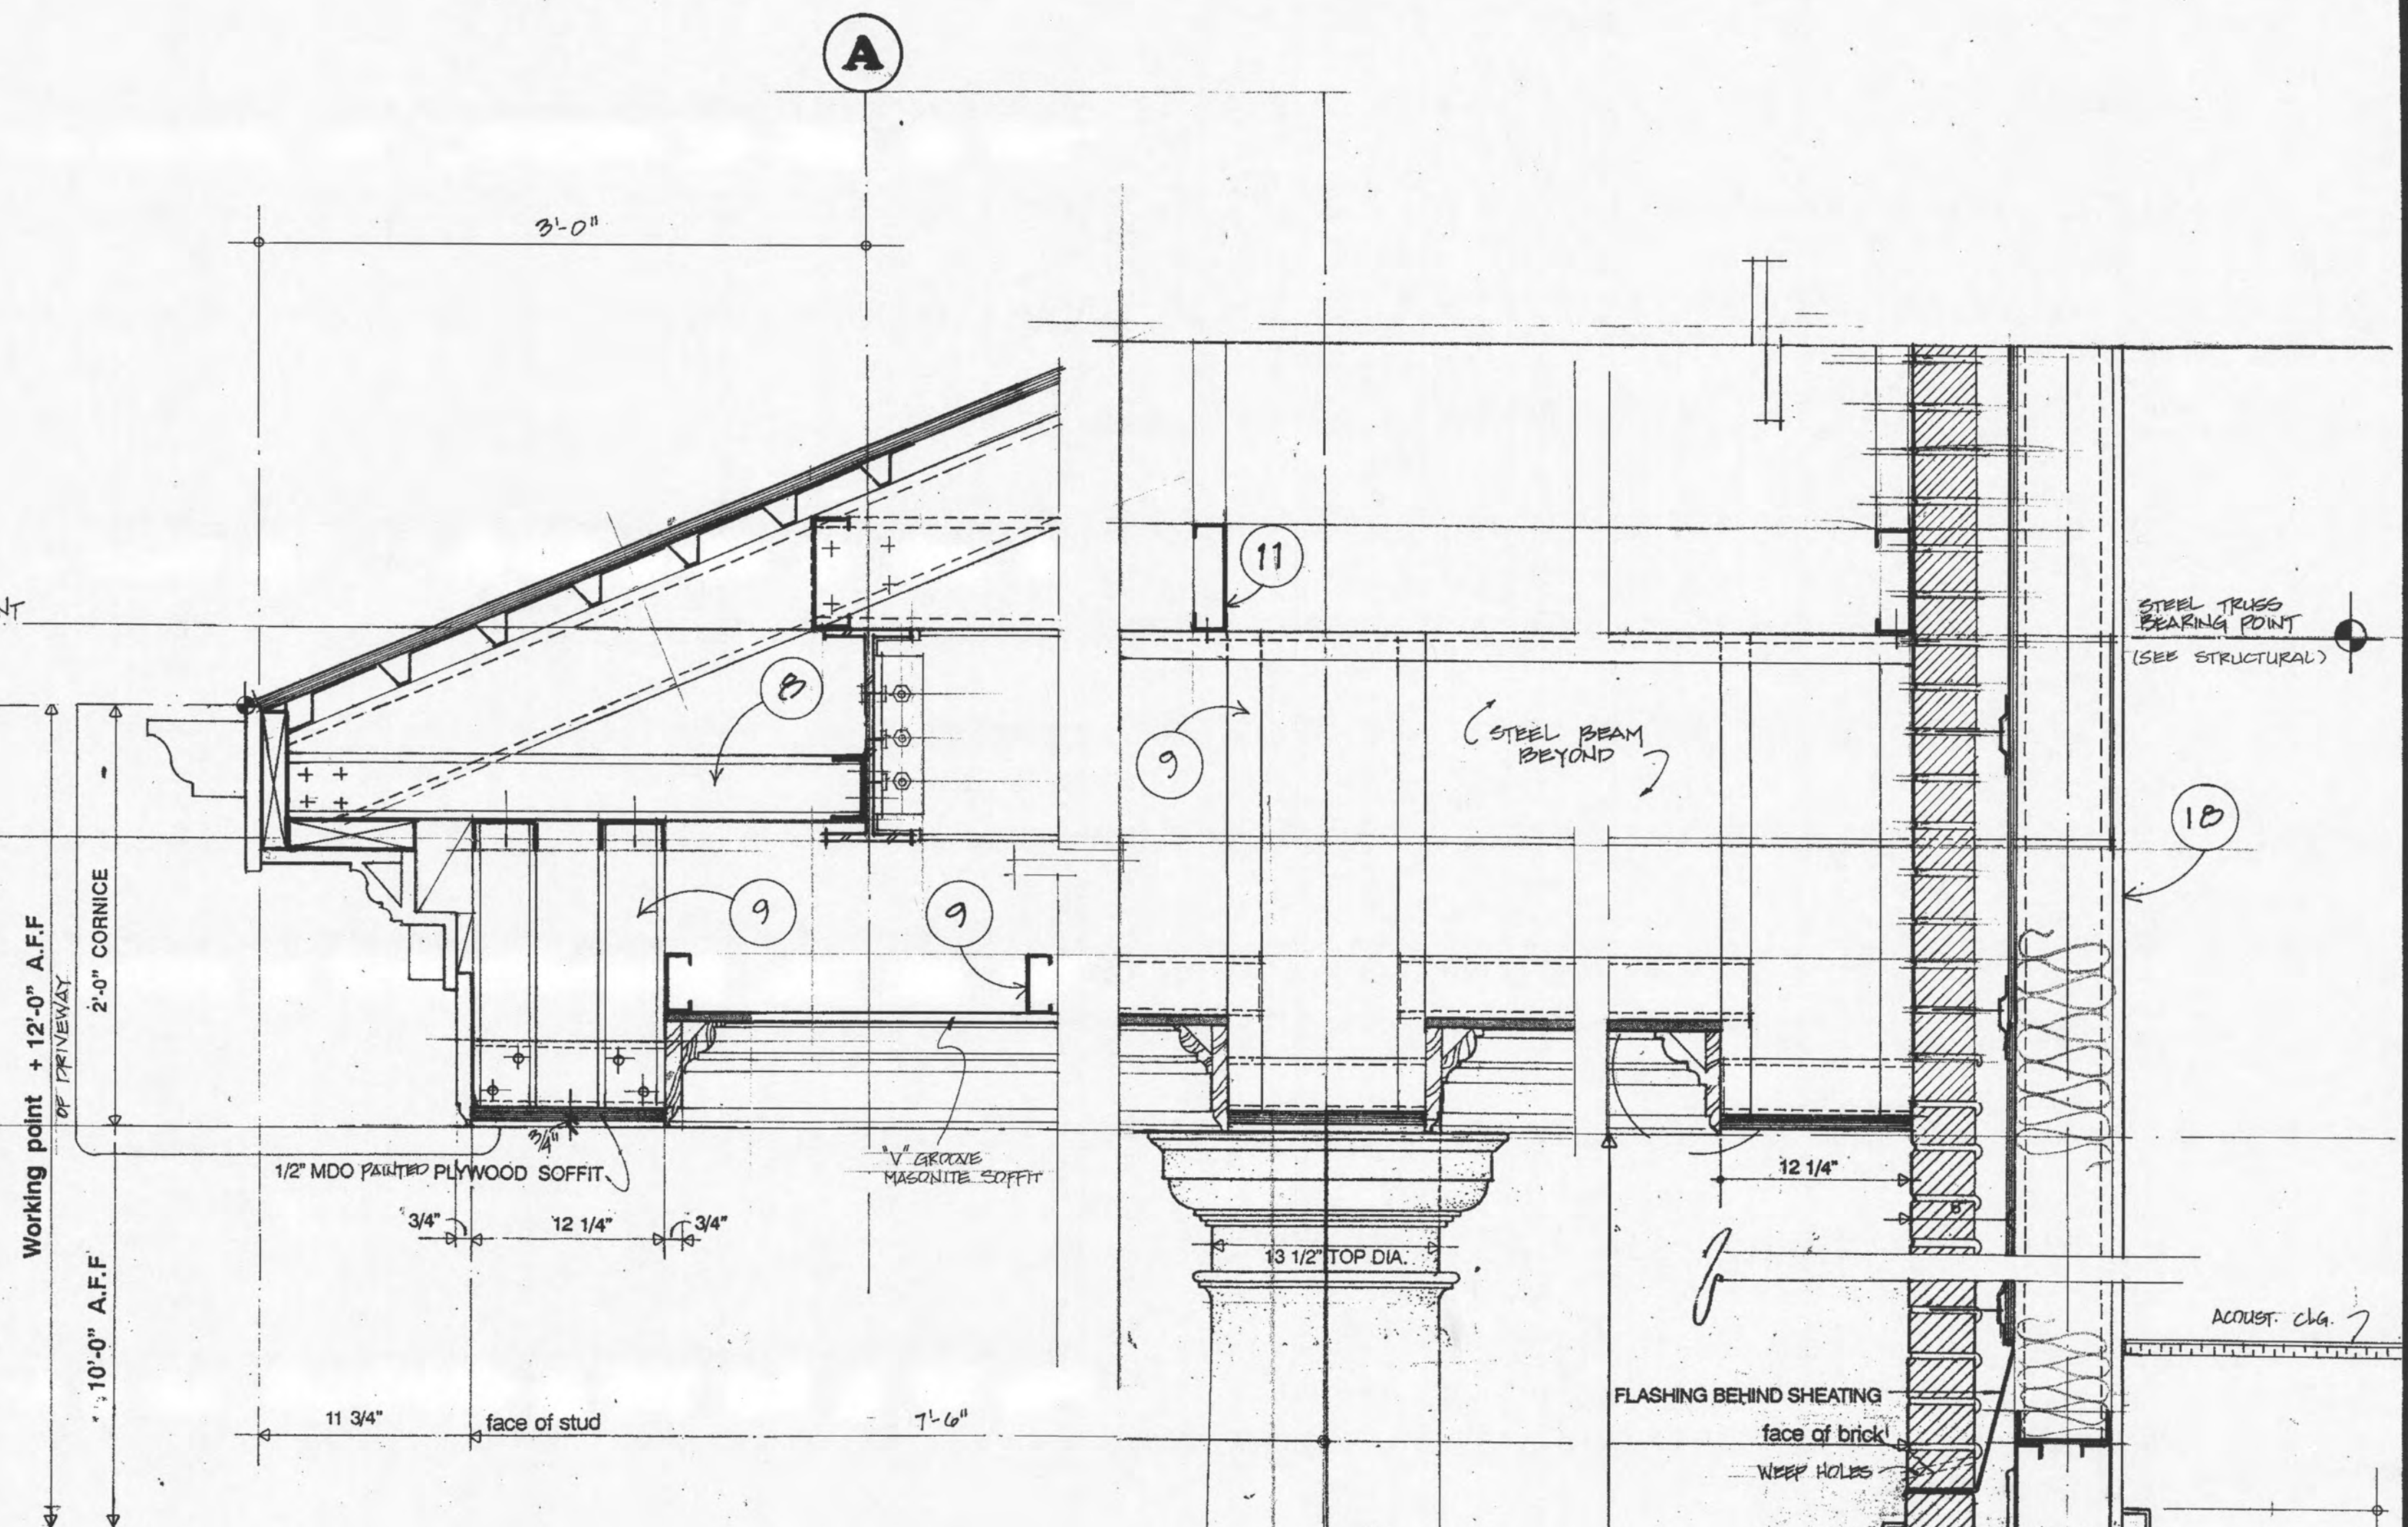



LEGEND

1. ASPHALT SHINGLES
2. FELT PAPER
3. 1/2" EXTERIOR SWEATHING
4. 1 1/2" DEEP METAL DECK
5. PREFINISHED DRAIN EDGE
6. PREFINISHED ALUMINUM GUTTER
7. STEEL BEAM (SEE STRUCT. DRWGS.)
8. 4" MTL STUDS @ 5'-0" O.C.
9. 4" MTL STUDS @ 16" O.C.
10. 6" MTL STUDS @ 16" O.C.
11. STEEL TRUSSES @ 5'-0" MAX. O.C. (SEE STRUCT. DRWGS.)
12. C-JOINT BLOCKING BETWEEN TRUSSES
13. STEEL JOIST (SEE STRUCT. DRWGS.)
14. CONCRETE SLAB
15. 6" BATT INSULATION
16. 8" BATT INSULATION W/ SUPPORT NET
17. 1/2" EXTERIOR SHEATHING
18. 1/2" INTERIOR GWS
19. BRICK VENEER W/ MTL. TIES @ 16" O.C.
20. THRU-WALL FLASHING
21. WEEP HOLES @ 4'-0" O.C.
22. GROUT SOLID
23. 4" NOMINAL CONC. BLOCK
24. 8" NOMINAL CONC. BLOCK
25. SPECIAL SHAPE EXTERIOR FINISH SYSTEM
26. EXTERIOR FINISH SYSTEM OVER 1/2" RIGID INSULATION
27. CONC. FOUNDATION WALLS (SEE STRUCT. DRWGS.)
28. WATER-PROOF MEMBRANE W/ 1" PROTECTIVE BOARD
29. 8" PERFORATED CORRUGATED PLASTIC TUBE FOOTING DRAIN WRAPPED IN FILTER PLASTIC
30. WATER STOP
31. VAPOR BARRIER
32. 4" GRAVEL
33. #4 STONE
34. 1 1/2" RIGID INSULATION ON Z FURRING
35. 12" VAULT WALL
36. 12" VAULT CEILING
37. SPRAYTEXTURE PAINT
38. 6"x2"x16" CONT. TUBE
39. PRECAST STONE COPING
40. SINGLE PLY ROOFING MEMBRANE
41. SINGLE PLY FLASHING MEMBRANE
42. TAPERED RIGID ROOF INSULATION
43. 12" CONCRETE CURB
44. BACK-UP ROD AND SEALANT

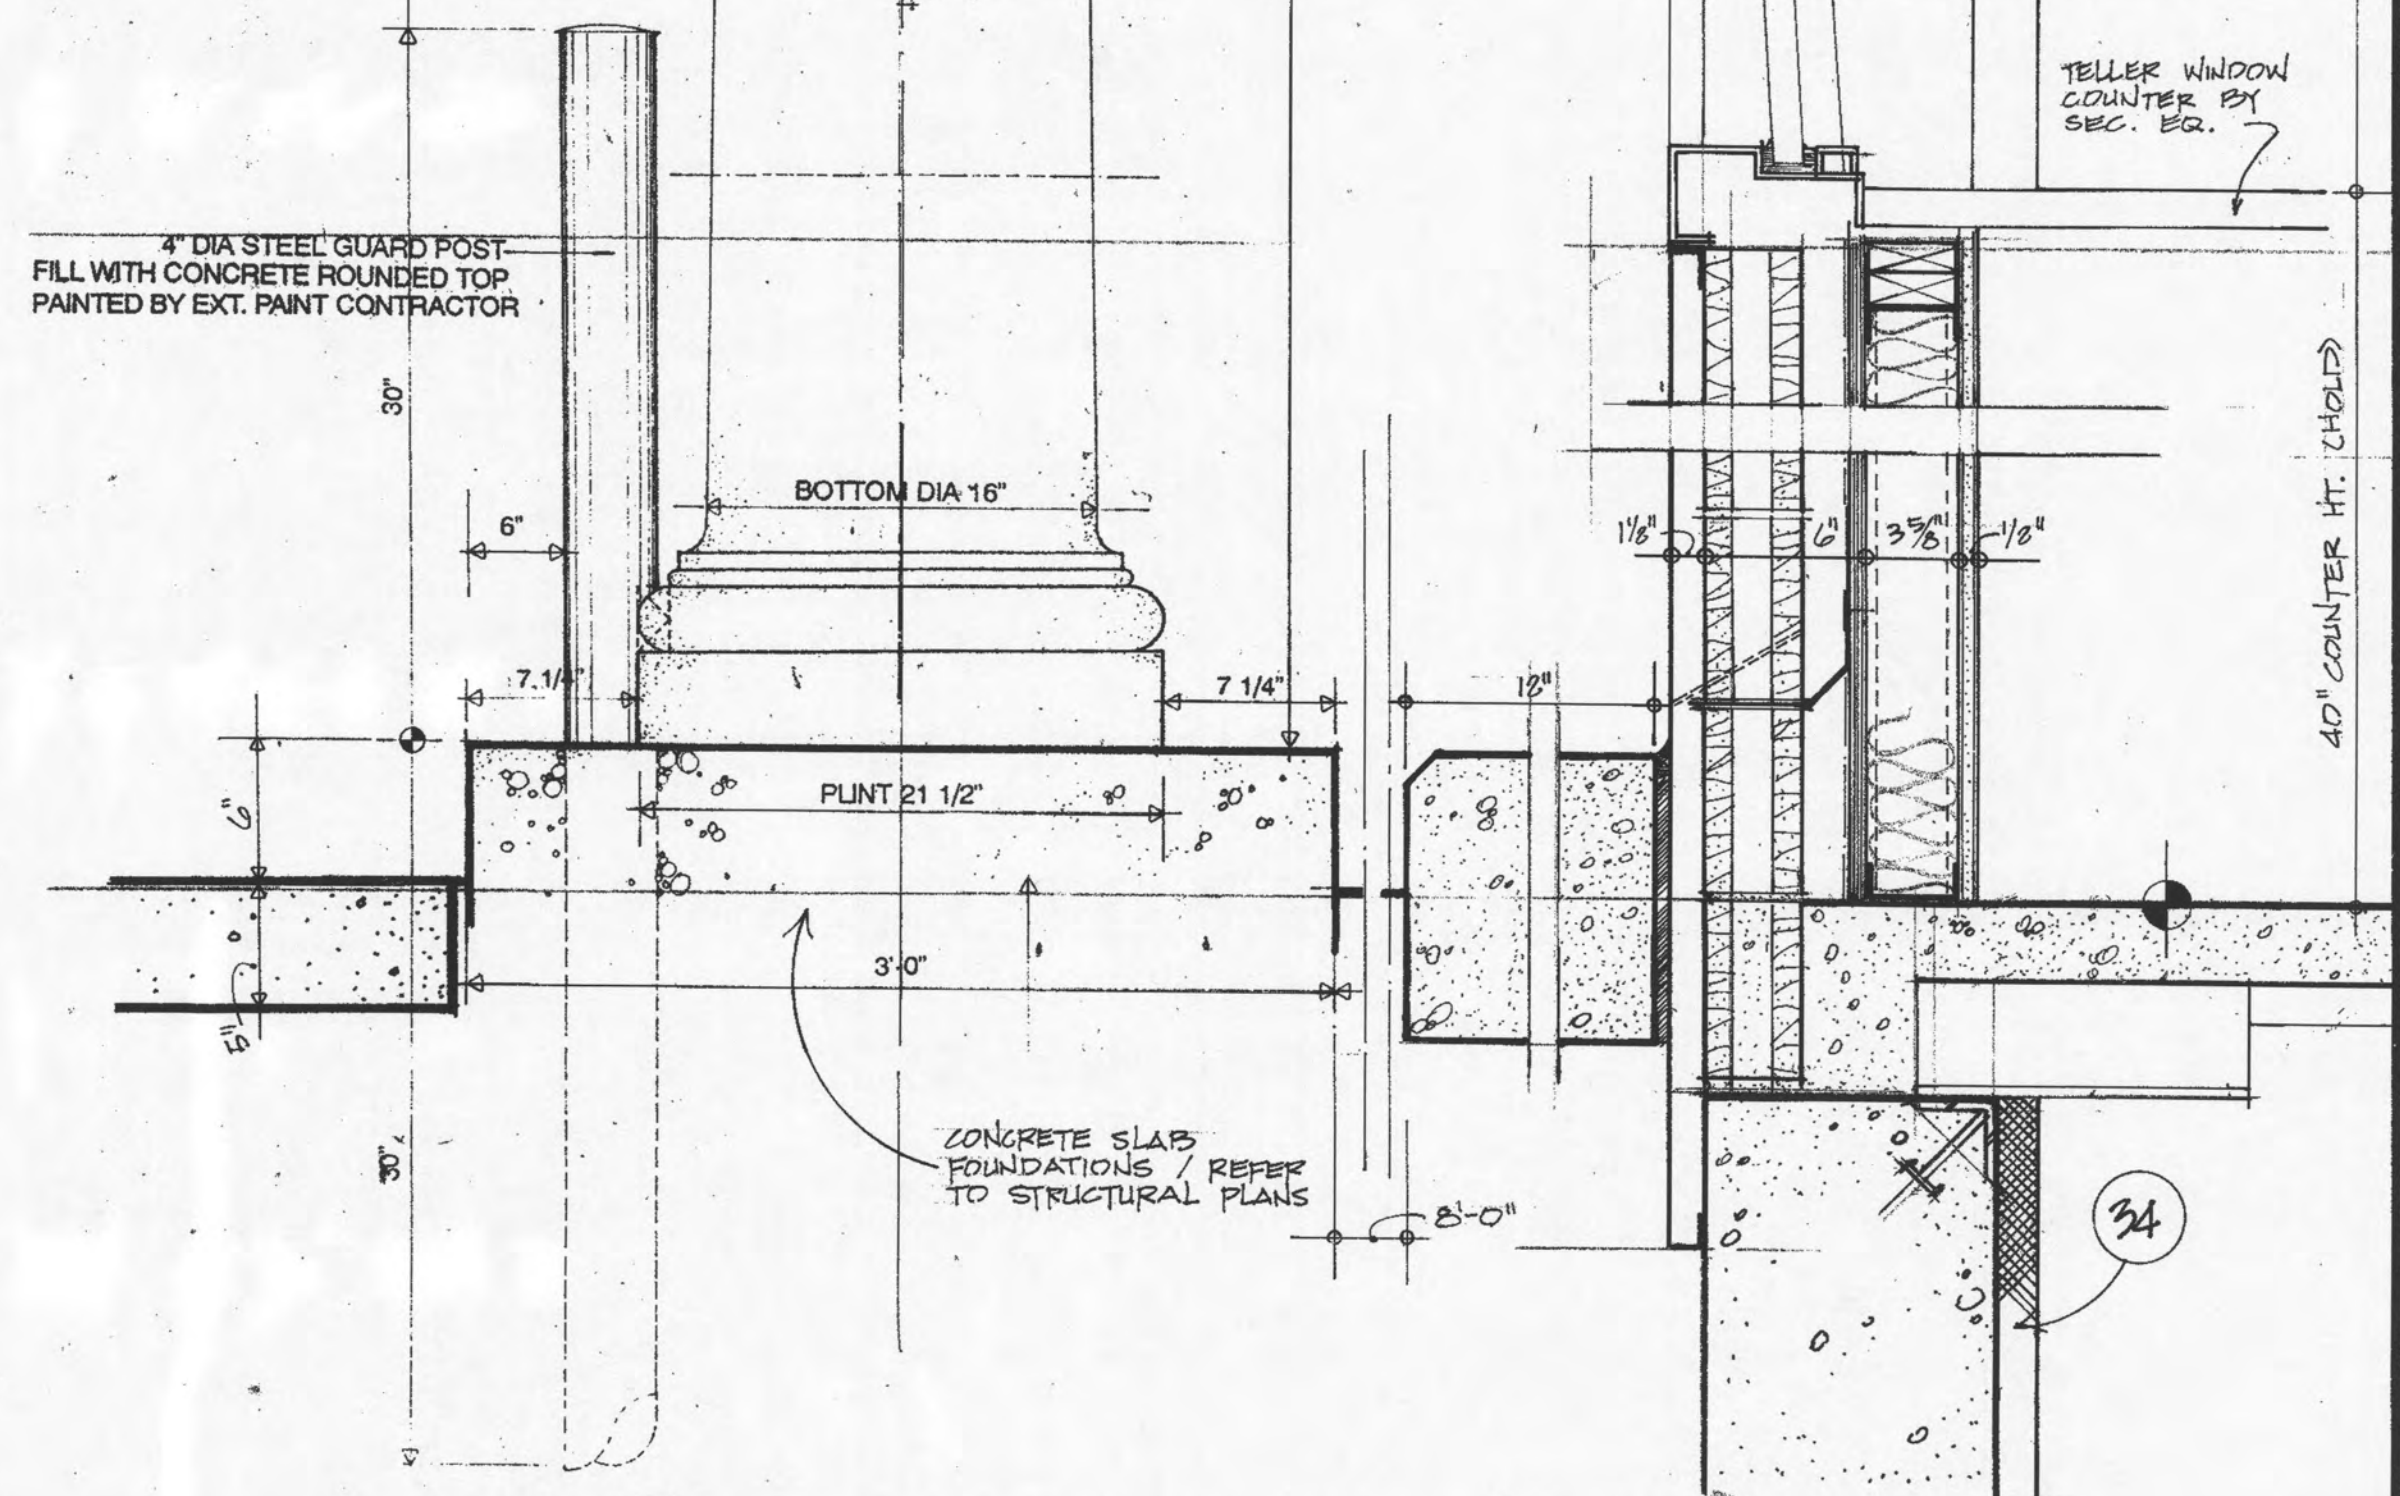

  2 WALL SECTION THRU DRIVE-UP WINDOW
A-19 SCALE: 1 1/2" = 1'-0"

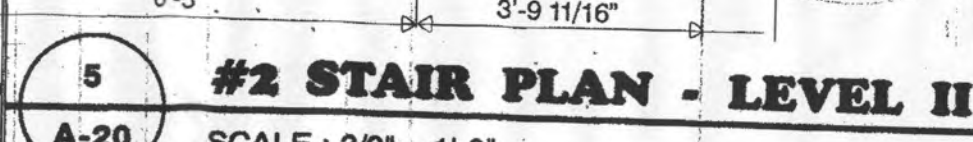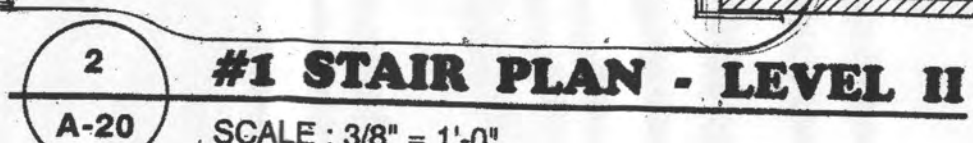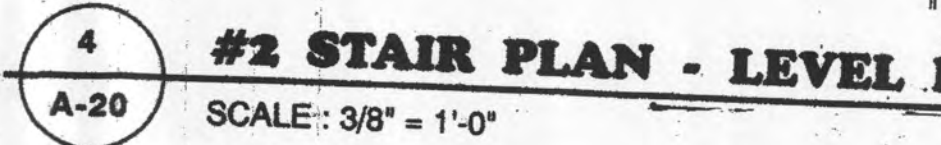



10

DOOR TYPES & FRAME SCHEDULE

No.	SIZE	TYPE	HD	JMB	SILL	CL	LOC	REMARKS
101	(2) 3'-0"X7'-0"X1 3/4"	D	8	13				PUSH/PULL ACTION
101A	(2) 3'-0"X7'-0"X1 3/4"	D	8	13				
101B	CASED OPENING	B	4	11				
102	3'-0"X7'-0"X1 3/4"	B	4	11				
103	ELEVATOR							"B" LABEL DOOR/FRAME
104	3'-0"X7'-0"X1 3/4"	A	4	11				MT DOOR
105	3'-0"X7'-0"X1 3/4"	A	4	11				
106	3'-0"X7'-0"X1 3/4"	A	4	11				
107	3'-0"X7'-0"X1 3/4"	A	4	11				
108	3'-0"X7'-0"X1 3/4"	A	4	11				
109	3'-0"X7'-0"X1 3/4"	A	4	11				
110	3'-0"X7'-0"X1 3/4"	A	4	11				
111	3'-0"X7'-0"X1 3/4"	A	4	11				
112	3'-0"X7'-0"X1 3/4"	A	4	11				
113	3'-0"X7'-0"X1 3/4"	A	4	11				
114	3'-0"X7'-0"X1 3/4"	A	4	11				
115	3'-0"X7'-0"X1 3/4"	A	4	11				
116	3'-0"X7'-0"X1 3/4"	A	4	11				
117	3'-0"X7'-0"X1 3/4"	A	4	11				
118	3'-0"X7'-0"X1 3/4"	A	4	11				
119	3'-0"X7'-0"X1 3/4"	A	4	11				
120	3'-0"X7'-0"X1 3/4"	A	4	11				
121	3'-0"X7'-0"X1 3/4"	A	4	11				
122	3'-0"X7'-0"X1 3/4"	A	4	11				
123	3'-0"X7'-0"X1 3/4"	A	4	11				
124	3'-0"X7'-0"X1 3/4"	A	4	11				
125	3'-0"X7'-0"X1 3/4"	A	4	11				
126	3'-0"X7'-0"X1 3/4"	A	4	11				
127	3'-0"X7'-0"X1 3/4"	A	4	11				
128	3'-0"X7'-0"X1 3/4"	A	4	11				
129	3'-0"X7'-0"X1 3/4"	A	4	11				
130	3'-0"X7'-0"X1 3/4"	A	4	11				
131	3'-0"X7'-0"X1 3/4"	A	4	11				
132	3'-0"X7'-0"X1 3/4"	A	4	11				
133	3'-0"X7'-0"X1 3/4"	A	4	11				
134	3'-0"X7'-0"X1 3/4"	A	4	11				
135	3'-0"X7'-0"X1 3/4"	A	4	11				
136	3'-0"X7'-0"X1 3/4"	A	4	11				
137	3'-0"X7'-0"X1 3/4"	A	4	11				
138	3'-0"X7'-0"X1 3/4"	A	4	11				
139	3'-0"X7'-0"X1 3/4"	A	4	11				
140	3'-0"X7'-0"X1 3/4"	A	4	11				
141	RECORD VAULT DOOR BY SECURITY EQUIPMENT CONTRACTOR							
142	3'-0"X7'-0"X1 3/4"	A	4	11				
143	3'-0"X7'-0"X1 3/4"	A	4	11				

201	(2) 3'-0"X7'-0"X1 3/4"	L	25	24				MT Door apply wood mould/B label door/frame & close 10x10 wired glass panel 1 1/2 hr unexposed side of door not to exceed 450
201A	(2) 3'-0"X7'-0"X1 3/4"	L	25	24				
202	ELEVATOR							"B" LABEL DOOR/FRAME
203	3'-0"X7'-0"X1 3/4"	A	4	11				
204	3'-0"X7'-0"X1 3/4"	A	4	11				
205	3'-0"X7'-0"X1 3/4"	A	4	11				
206	3'-0"X7'-0"X1 3/4"	A	4	11				
207	3'-0"X7'-0"X1 3/4"	A	4	11				
208	3'-0"X7'-0"X1 3/4"	A	4	11				
209	3'-0"X7'-0"X1 3/4"	A	4	11				
210	3'-0"X7'-0"X1 3/4"	A	4	11				
211	3'-0"X7'-0"X1 3/4"	A	4	11				
212	3'-0"X7'-0"X1 3/4"	A	4	11				
213	3'-0"X7'-0"X1 3/4"	A	4	11				
214	3'-0"X7'-0"X1 3/4"	A	4	11				
215	3'-0"X7'-0"X1 3/4"	A	4	11				
216	3'-0"X7'-0"X1 3/4"	A	4	11				
217	3'-0"X7'-0"X1 3/4"	A	4	11				
218	3'-0"X7'-0"X1 3/4"	A	4	11				
219	3'-0"X7'-0"X1 3/4"	A	4	11				
220	3'-0"X7'-0"X1 3/4"	A	4	11				
221	3'-0"X7'-0"X1 3/4"	A	4	11				
222	3'-0"X7'-0"X1 3/4"	A	4	11				
223	3'-0"X7'-0"X1 3/4"	A	4	11				
224	RECORD VAULT DOOR BY SECURITY EQUIPMENT CONTRACTOR							
225	3'-0"X7'-0"X1 3/4"	A	4	11				
226	3'-0"X7'-0"X1 3/4"	A	4	11				
227	3'-0"X7'-0"X1 3/4"	A	4	11				
228	3'-0"X7'-0"X1 3/4"	A	4	11				
229	3'-0"X7'-0"X1 3/4"	A	4	11				
230	3'-0"X7'-0"X1 3/4"	A	4	11				
231	3'-0"X7'-0"X1 3/4"	A	4	11				
232	3'-0"X7'-0"X1 3/4"	A	4	11				
233	3'-0"X7'-0"X1 3/4"	A	4	11				
234	RECORD VAULT DOOR BY SECURITY EQUIPMENT CONTRACTOR							
235	3'-0"X7'-0"X1 3/4"	A	4	11				
236	3'-0"X7'-0"X1 3/4"	A	4	11				
237	3'-0"X7'-0"X1 3/4"	A	4	11				
238	3'-0"X7'-0"X1 3/4"	A	4	11				
239	3'-0"X7'-0"X1 3/4"	A	4	11				
240	3'-0"X7'-0"X1 3/4"	A	4	11				
241	3'-0"X7'-0"X1 3/4"	A	4	11				
242	3'-0"X7'-0"X1 3/4"	A	4	11				
243	3'-0"X7'-0"X1 3/4"	A	4	11				
244	3'-0"X7'-0"X1 3/4"	A	4	11				
245	3'-0"X7'-0"X1 3/4"	A	4	11				
246	3'-0"X7'-0"X1 3/4"	A	4	11				
247	3'-0"X7'-0"X1 3/4"	A	4	11				
248	3'-0"X7'-0"X1 3/4"	A	4	11				

301	CASED OPENING	A	4	11				
302	3'-0"X7'-0"X1 3/4"	A	4	11				
303	ELEVATOR							"B" LABEL DOOR/FRAME
304	3'-0"X7'-0"X1 3/4"	A	4	11				
305	3'-0"X7'-0"X1 3/4"	A	4	11				
306	3'-0"X7'-0"X1 3/4"	A	4	11				
307	3'-0"X7'-0"X1 3/4"	A	4	11				
308	CASED OPENING	A	4	11				
309	3'-0"X7'-0"X1 3/4"	A	4	11				
310	3'-0"X7'-0"X1 3/4"	A	4	11				
311	RECORD VAULT DOOR BY SECURITY EQUIPMENT CONTRACTOR							
312	3'-0"X7'-0"X1 3/4"	A	4	11				
313	3'-0"X7'-0"X1 3/4"	A	4	11				
314	3'-0"X7'-0"X1 3/4"	A	4	11				
315	3'-0"X7'-0"X1 3/4"	A	4	11				
316	3'-0"X7'-0"X1 3/4"	A	4	11				
317	3'-0"X7'-0"X1 3/4"	A	4	11				
318	3'-0"X7'-0"X1 3/4"	A	4	11				
319	3'-0"X7'-0"X1 3/4"	A	4	11				
320	3'-0"X7'-0"X1 3/4"	A	4	11				
321	3'-0"X7'-0"X1 3/4"	A	4	11				
322	3'-0"X7'-0"X1 3/4"	A	4	11				
323	3'-0"X7'-0"X1 3/4"	A	4	11				
324	3'-0"X7'-0"X1 3/4"	A	4	11				
325	3'-0"X7'-0"X1 3/4"	A	4	11				
326	3'-0"X7'-0"X1 3/4"	A	4	11				
327	3'-0"X7'-0"X1 3/4"	A	4	11				
328	3'-0"X7'-0"X1 3/4"	A	4	11				
329	3'-0"X7'-0"X1 3/4"	A	4	11				
330	3'-0"X7'-0"X1 3/4"	A	4	11				
331	3'-0"X7'-0"X1 3/4"	A	4	11				
332	3'-0"X7'-0"X1 3/4"	A	4	11				
333	3'-0"X7'-0"X1 3/4"	A	4	11				
334	3'-0"X7'-0"X1 3/4"	A	4	11				
335	3'-0"X7'-0"X1 3/4"	A	4	11				
336	3'-0"X7'-0"X1 3/4"	A	4	11				
337	3'-0"X7'-0"X1 3/4"	A	4	11				
338	3'-0"X7'-0"X1 3/4"	A	4	11				
339	3'-0"X7'-0"X1 3/4"	A	4	11				
340	3'-0"X7'-0"X1 3/4"	A	4	11				
341	3'-0"X7'-0"X1 3/4"	A	4	11				
342	3'-0"X7'-0"X1 3/4"	A	4	11				
343	3'-0"X7'-0"X1 3/4"	A	4	11				
344	3'-0"X7'-0"X1 3/4"	A	4	11				
345	3'-0"X7'-0"X1 3/4"	A	4	11				
346	3'-0"X7'-0"X1 3/4"	A	4	11				
347	3'-0"X7'-0"X1 3/4"	A	4	11				
348	3'-0"X7'-0"X1 3/4"	A	4	11				
349	3'-0"X7'-0"X1 3/4"	A	4	11				
350	3'-0"X7'-0"X1 3/4"	A	4	11				

351	RECORD VAULT DOOR BY SECURITY EQUIPMENT CONTRACTOR							
352	3'-0"X7'-0"X1 3/4"	A	4	11				
353	3'-0"X7'-0"X1 3/4"	A	4	11				
354	3'-0"X7'-0"X1 3/4"	A	4	11				
355	3'-0"X7'-0"X1 3/4"	A	4	11				
356	3'-0"X7'-0"X1 3/4"	A	4	11				
357	3'-0"X7'-0"X1 3/4"	A	4	11				
358	3'-0"X7'-0"X1 3/4"	A	4	11				
359	3'-0"X7'-0"X1 3/4"	A	4	11				
360	3'-0"X7'-0"X1 3/4"	A	4	11				
361	3'-0"X7'-0"X1 3/4"	A	4	11				
362	3'-0"X7'-0"X1 3/4"	A	4	11				
363	3'-0"X7'-0"X1 3/4"	A	4	11				
364	3'-0"X7'-0"X1 3/4"	A	4	11				
365	3'-0"X7'-0"X1 3/4"	A	4	11				
366	3'-0"X7'-0"X1 3/4"	A	4	11				
367	3'-0"X7'-0"X1 3/4"	A	4	11				
368	3'-0"X7'-0"X1 3/4"	A	4	11				
369	3'-0"X7'-0"X1 3/4"	A	4	11				
370	3'-0"X7'-0"X1 3/4"	A	4	11				
371	3'-0"X7'-0"X1 3/4"	A	4	11				
372	3'-0"X7'-0"X1 3/4"	A	4	11				
373	3'-0"X7'-0"X1 3/4"	A	4	11				
374	3'-0"X7'-0"X1 3/4"	A	4	11				
375	3'-0"X7'-0"X1 3/4"	A	4	11				
376	3'-0"X7'-0"X1 3/4"	A	4	11				
377	3'-0"X7'-0"X1 3/4"	A	4	11				
378	3'-0"X7'-0"X1 3/4"	A	4	11				
379	3'-0"X7'-0"X1 3/4"	A	4	11				
380	3'-0"X7'-0"X1 3/4"	A	4	11				


Architectural drawing of a gallery elevation. The drawing shows a section of a wall with a refrigerator and two doors. The refrigerator is labeled "REFRIGERATOR" and has a width of 23'. To the left of the refrigerator is a section 38' wide. To the right of the refrigerator are two doors, each labeled "D.M.R.". The distance between the refrigerator and the first door is 8'-0 1/2", and the distance between the two doors is 8'-0 1/2". The total width of the section shown is 54'-0 1/2".

1
A 23


GALLERY ELEVATION

SCALE: 1/2" = 1'-0"


2
A 23

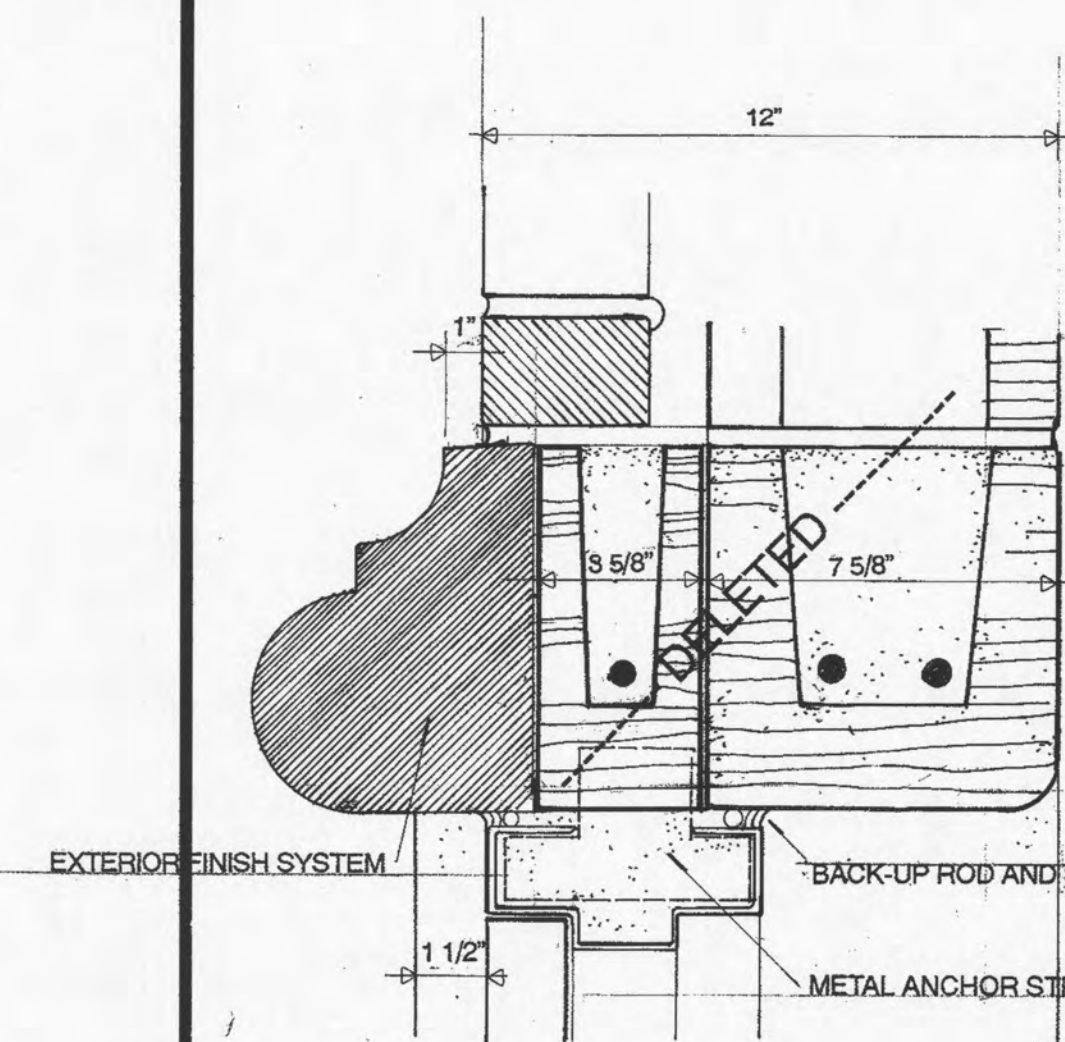


1 HEAD DETAIL
A 24 SCALE 3"=1'-0"

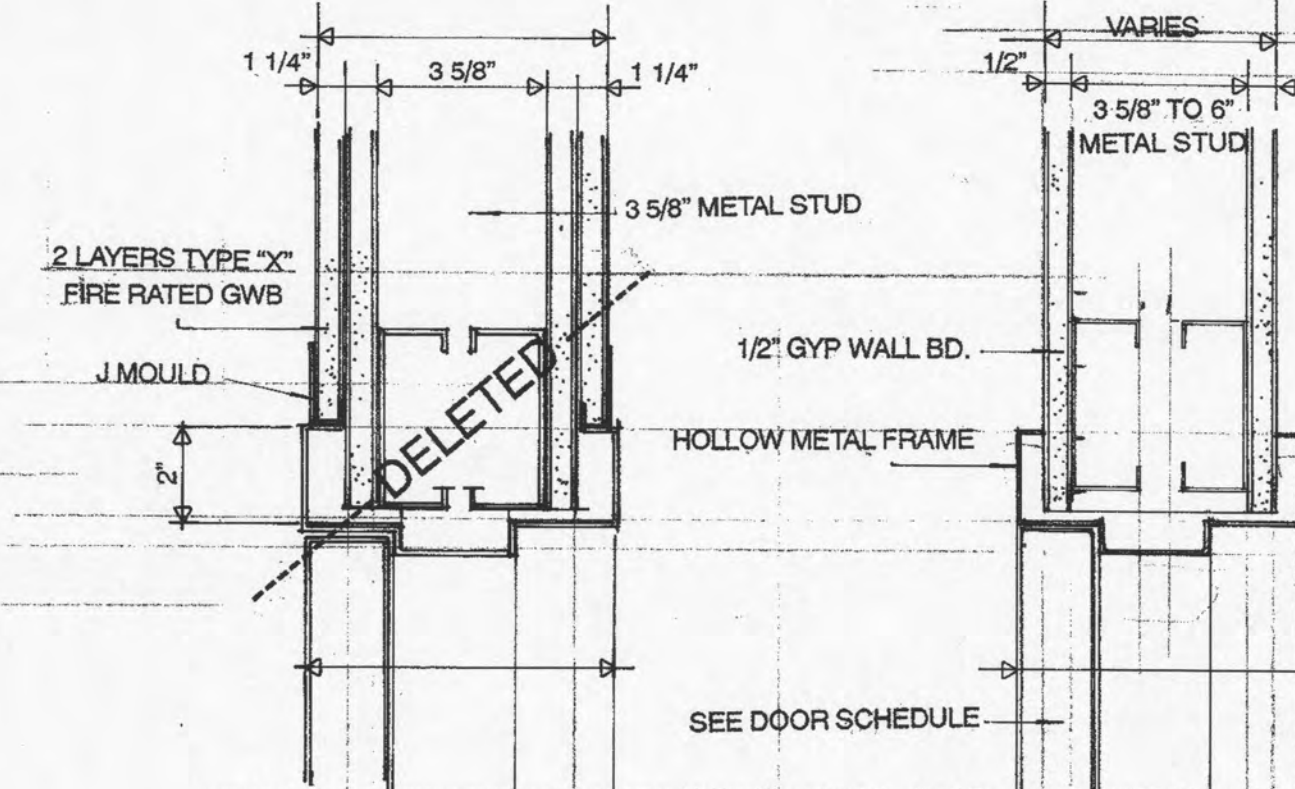


2 HEAD DETAIL
A 24 SCALE 3"=1'-0"

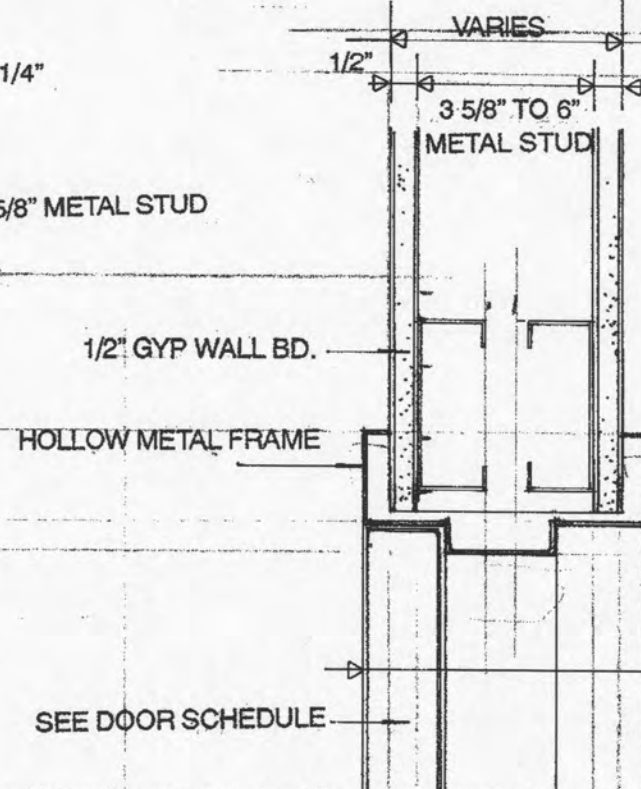


3 HEAD DETAIL
A 24 SCALE 3"=1'-0"

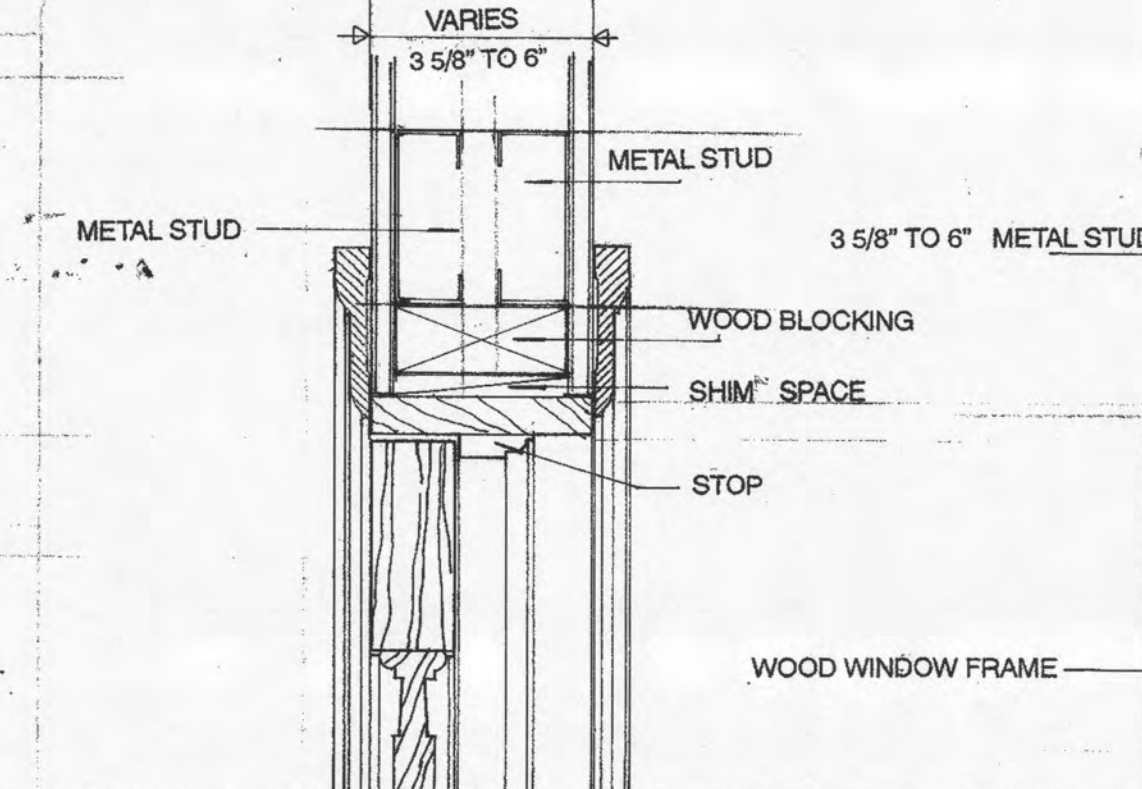


4 HEAD DETAIL
A 24 SCALE 3"=1'-0"

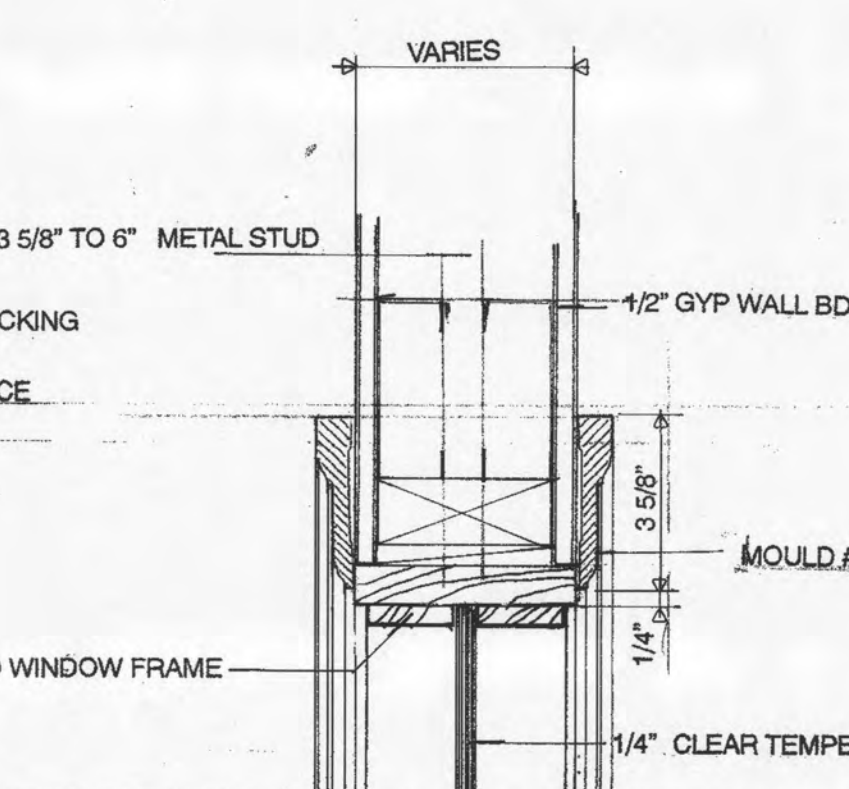


5 HEAD DETAIL
A 24 SCALE 3"=1'-0"

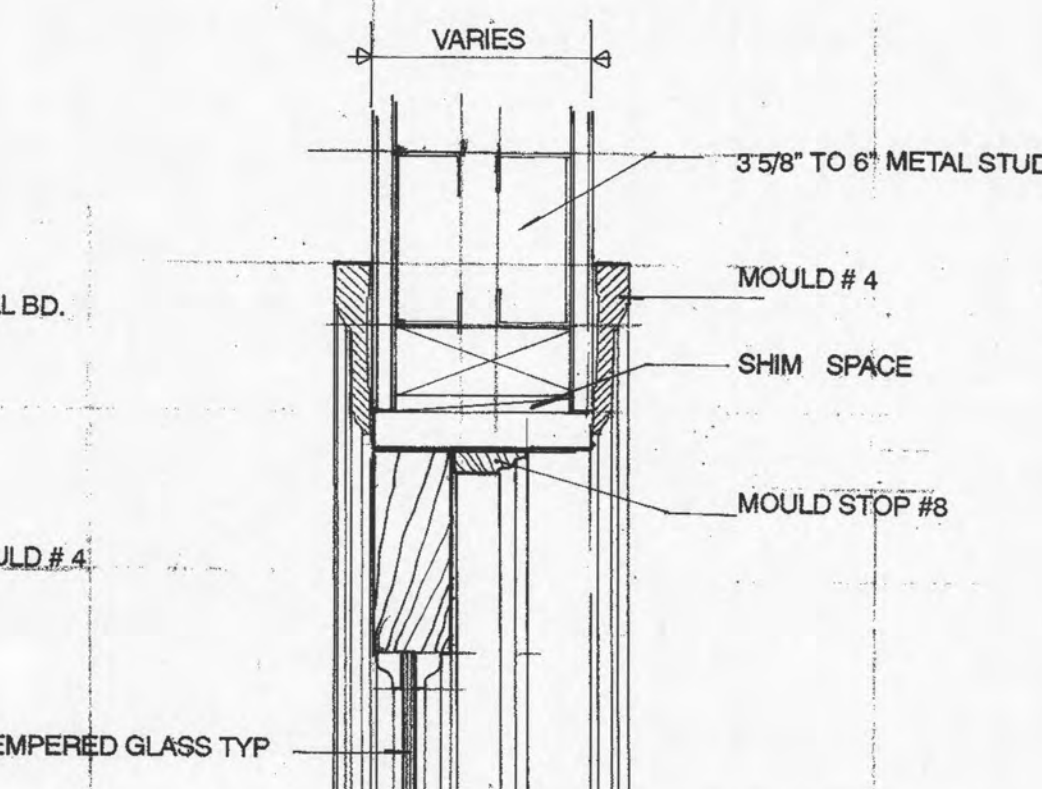


6 HEAD DETAIL
A 24 SCALE 3"=1'-0"

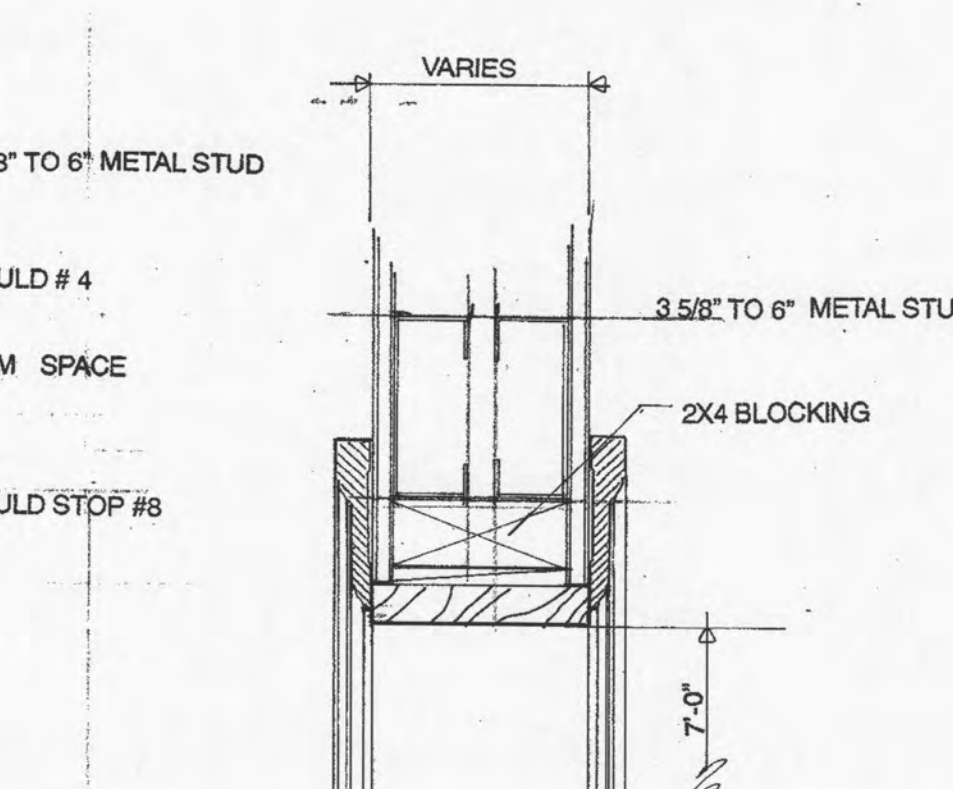


7 HEAD DETAIL
A 24 SCALE 3"=1'-0"

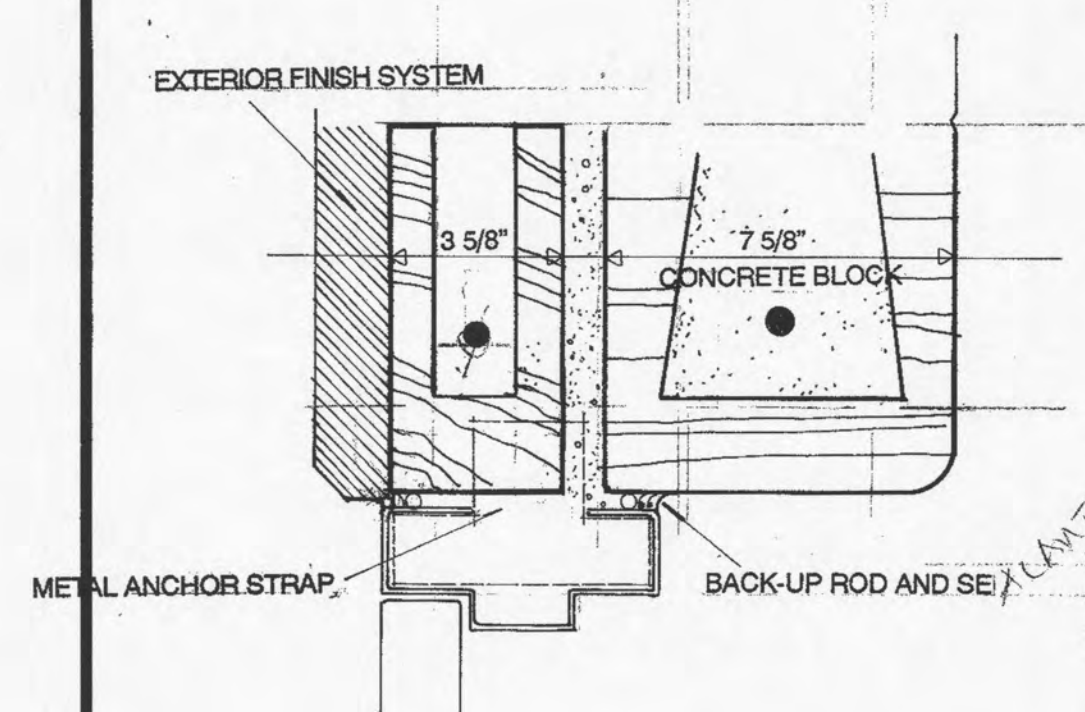


8 JAMB DETAIL
A 24 SCALE 3"=1'-0"
@ DOOR # 216

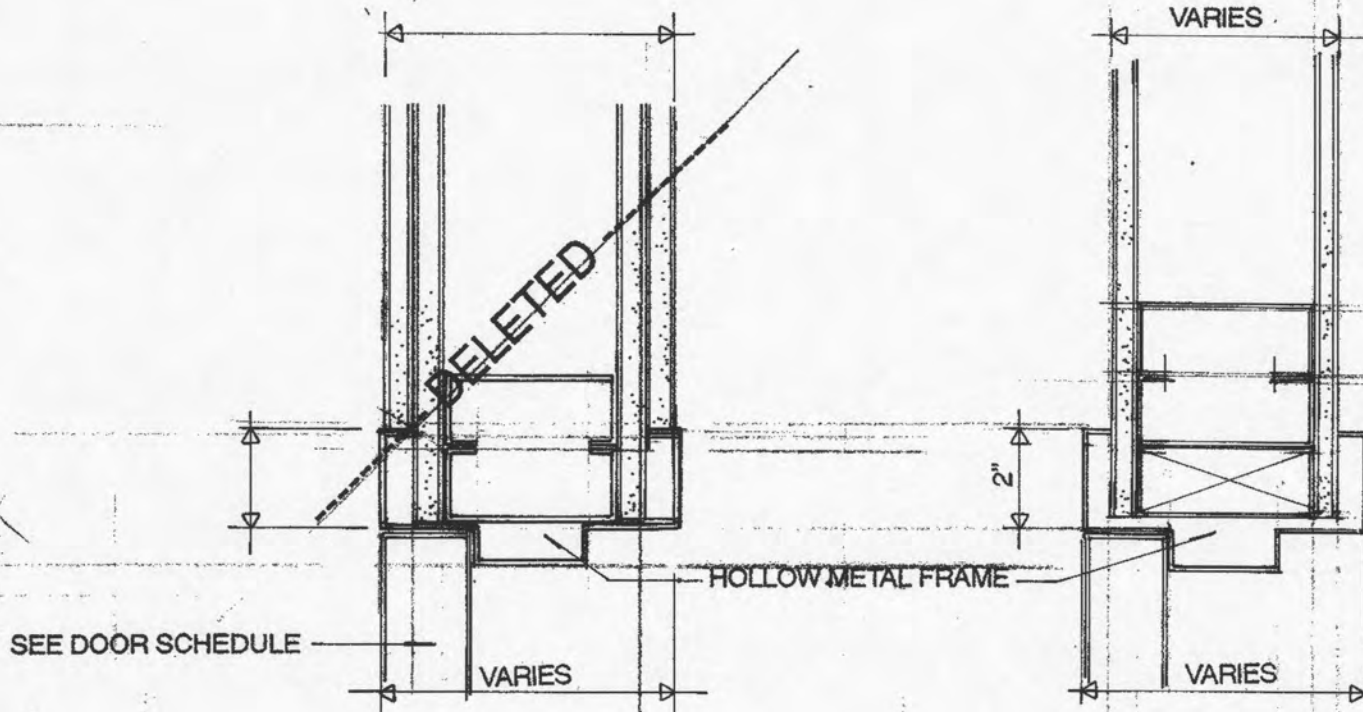


9 JAMB DETAIL
A 24 SCALE 3"=1'-0"
@ DOOR # 311 (Record Vault)

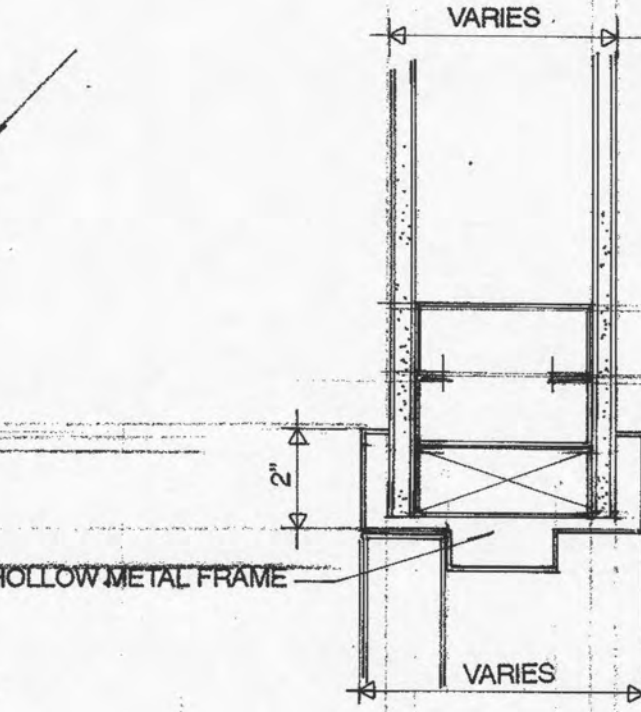


10 JAMB DETAIL
A 24 SCALE 3"=1'-0"
@ DOOR # 117

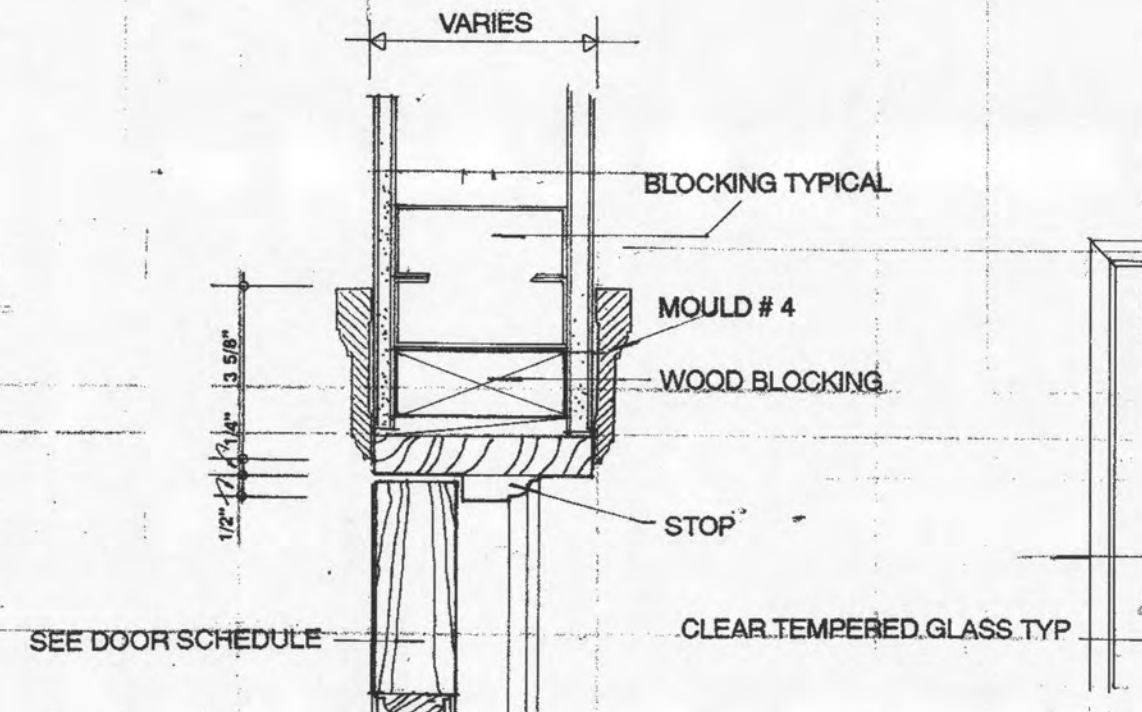


11 JAMB DETAIL
A 24 SCALE 3"=1'-0"

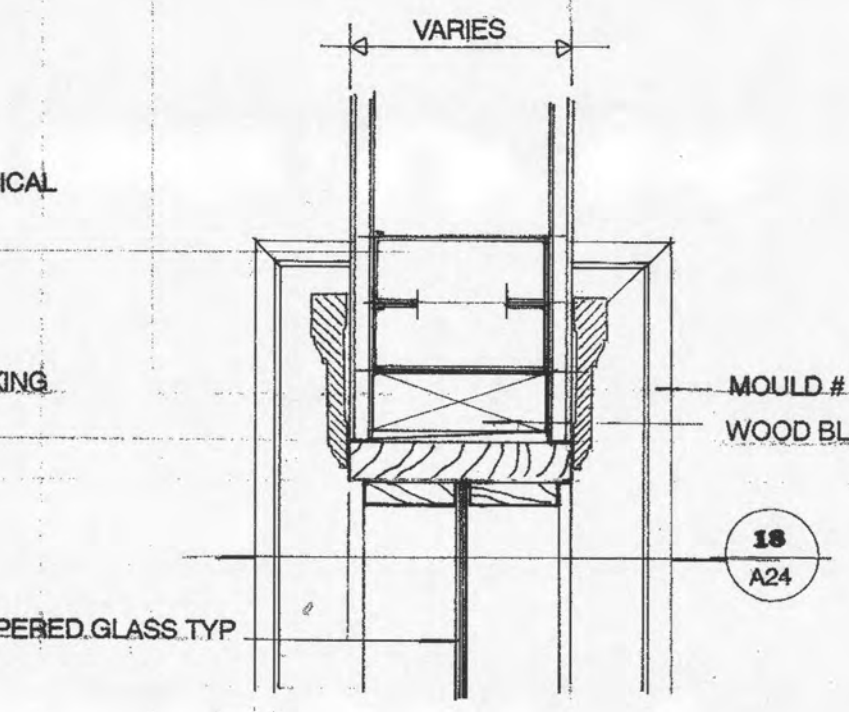


12 JAMB DETAIL
A 24 SCALE 3"=1'-0"

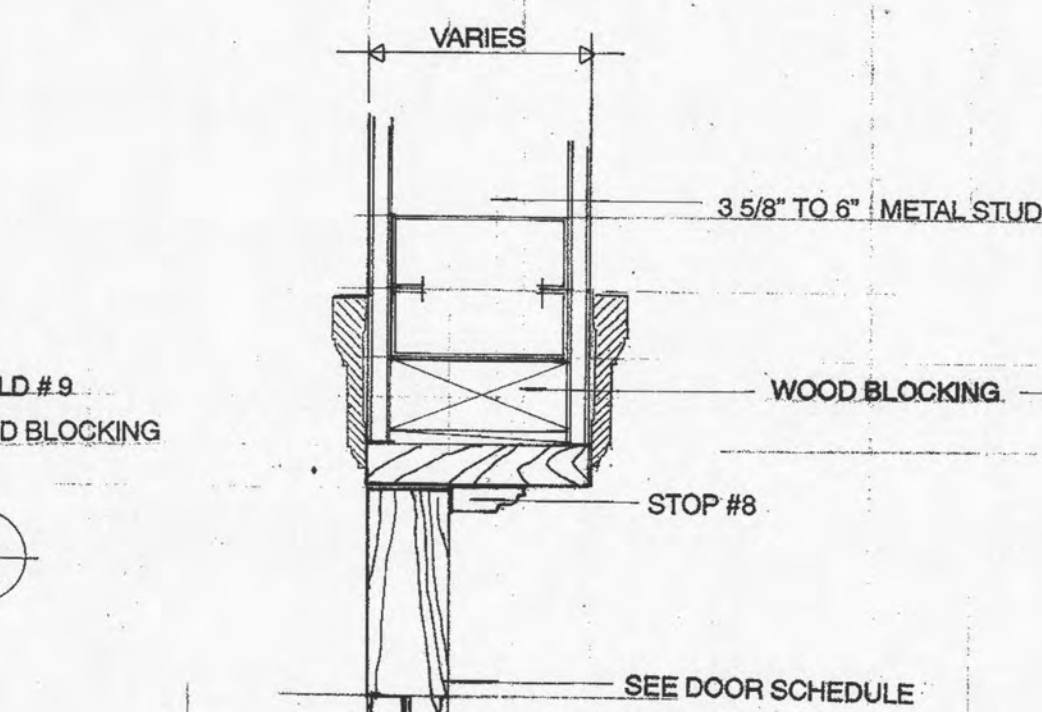


13 JAMB DETAIL
A 24 SCALE 3"=1'-0"

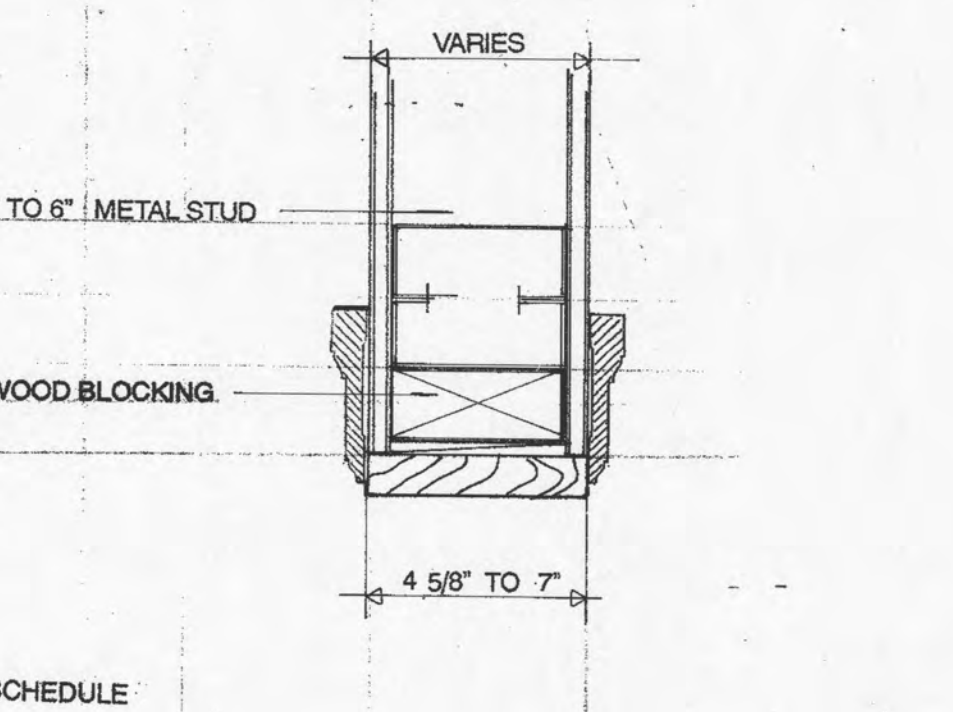


14 JAMB DETAIL
A 24 SCALE 3"=1'-0"

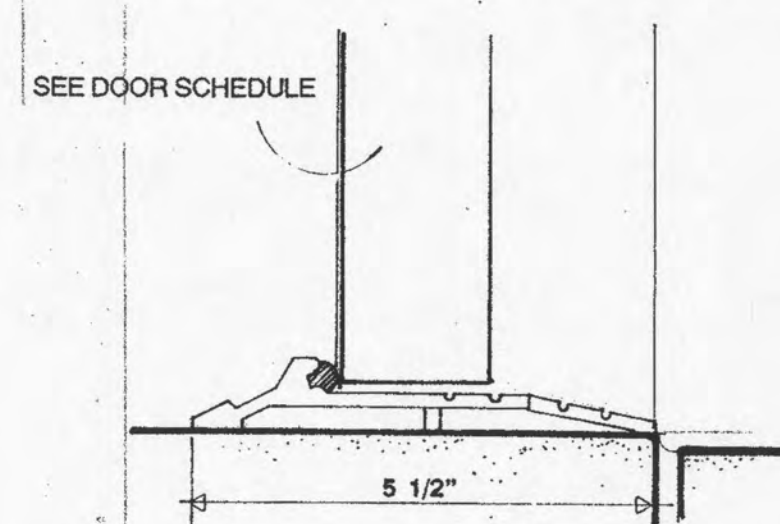


15 SILL DETAIL
A 24 SCALE 3"=1'-0"

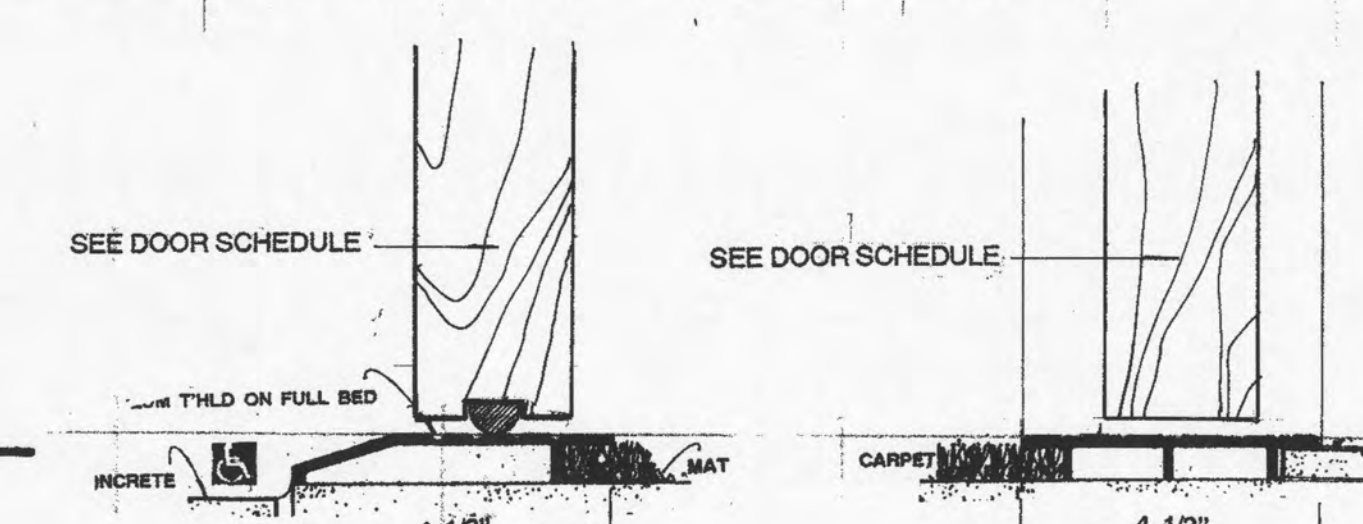


16 SILL DETAIL
A 24 SCALE 3"=1'-0"

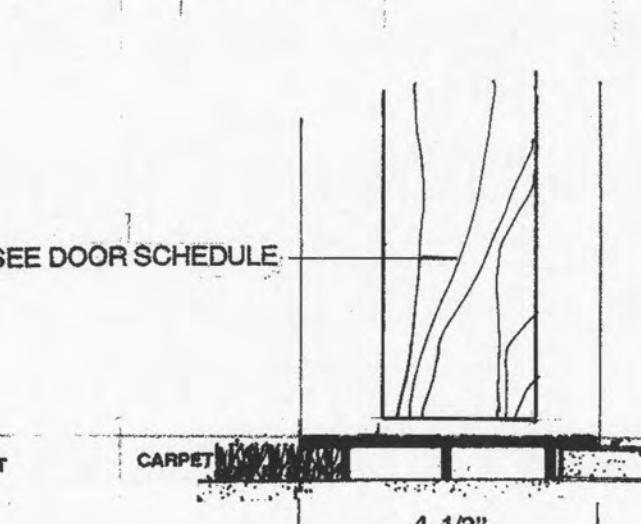

17 SILL DETAIL
A 24 SCALE 3"=1'-0"

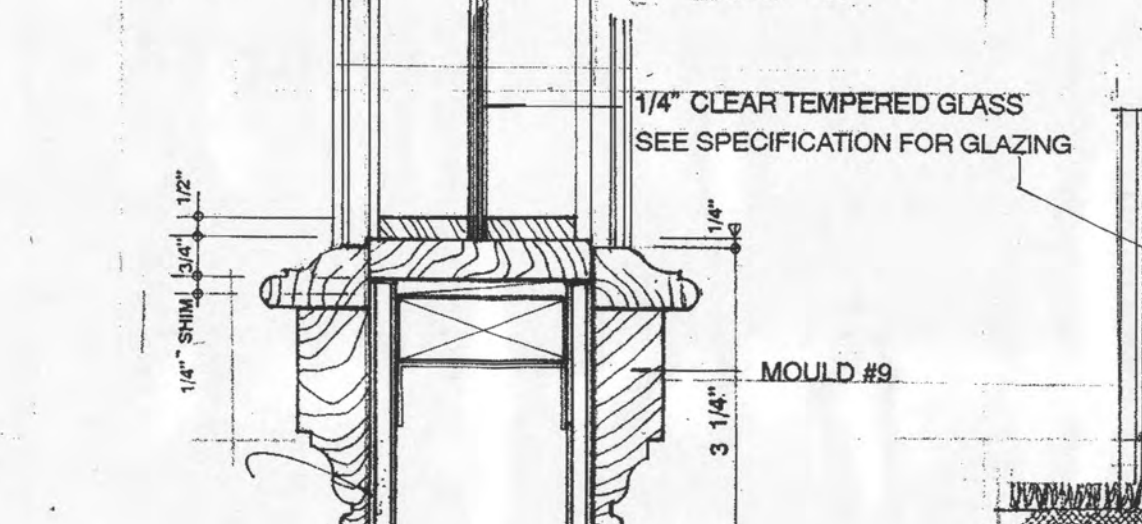


18 SILL DETAIL
A 24 SCALE 3"=1'-0"

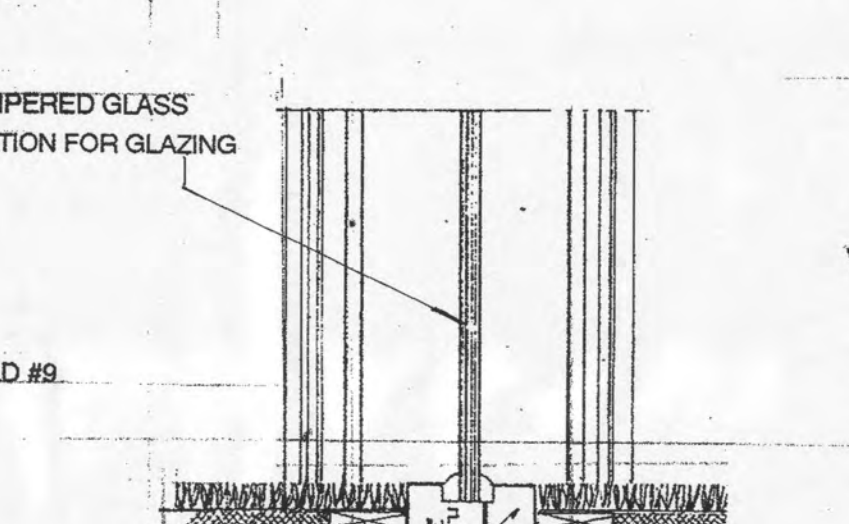


19 SILL DETAIL
A 24 SCALE 3"=1'-0"




20 SILL DETAIL
A 24 SCALE 3"=1'-0"

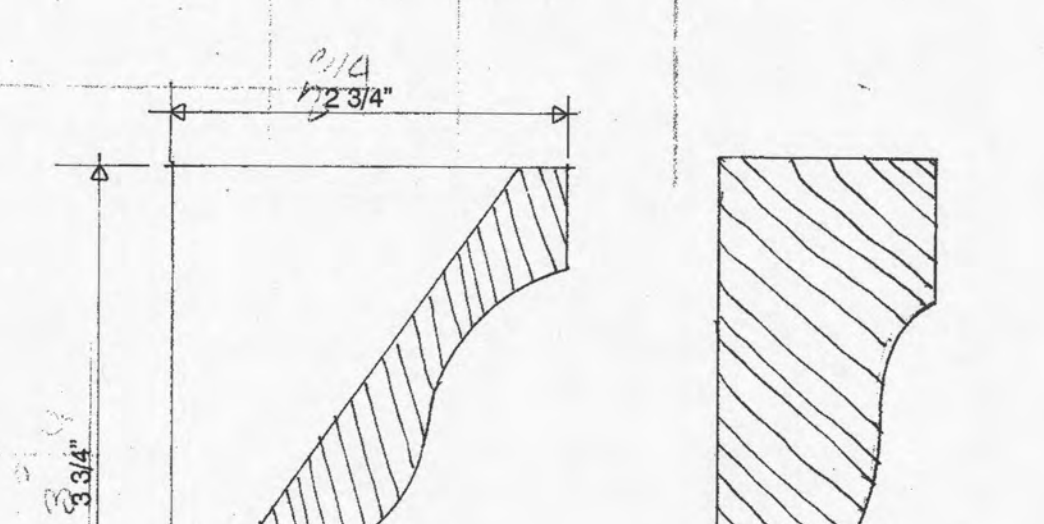


21 SILL DETAIL
A 24 SCALE 3"=1'-0"

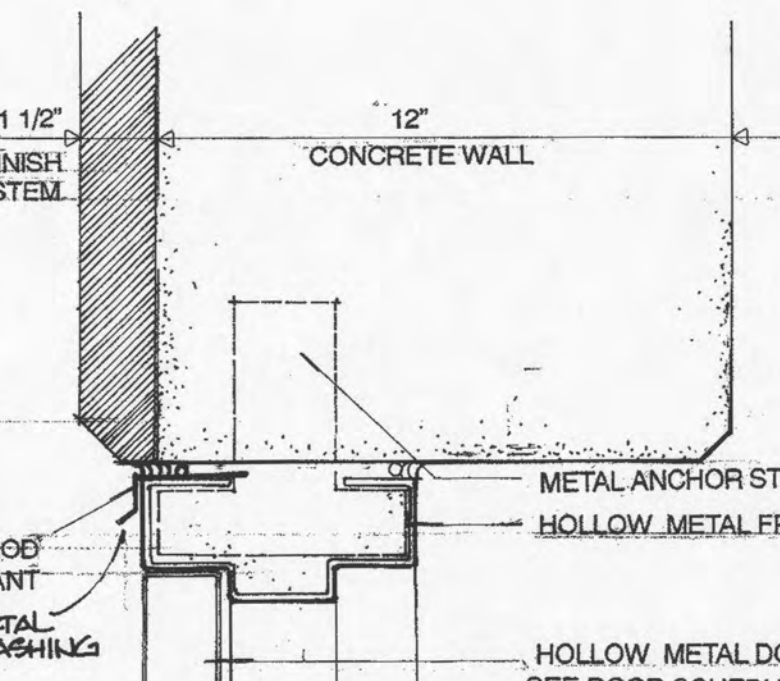


22 HEAD DETAIL
A 24 SCALE 3"=1'-0"
@ DOOR # 116A

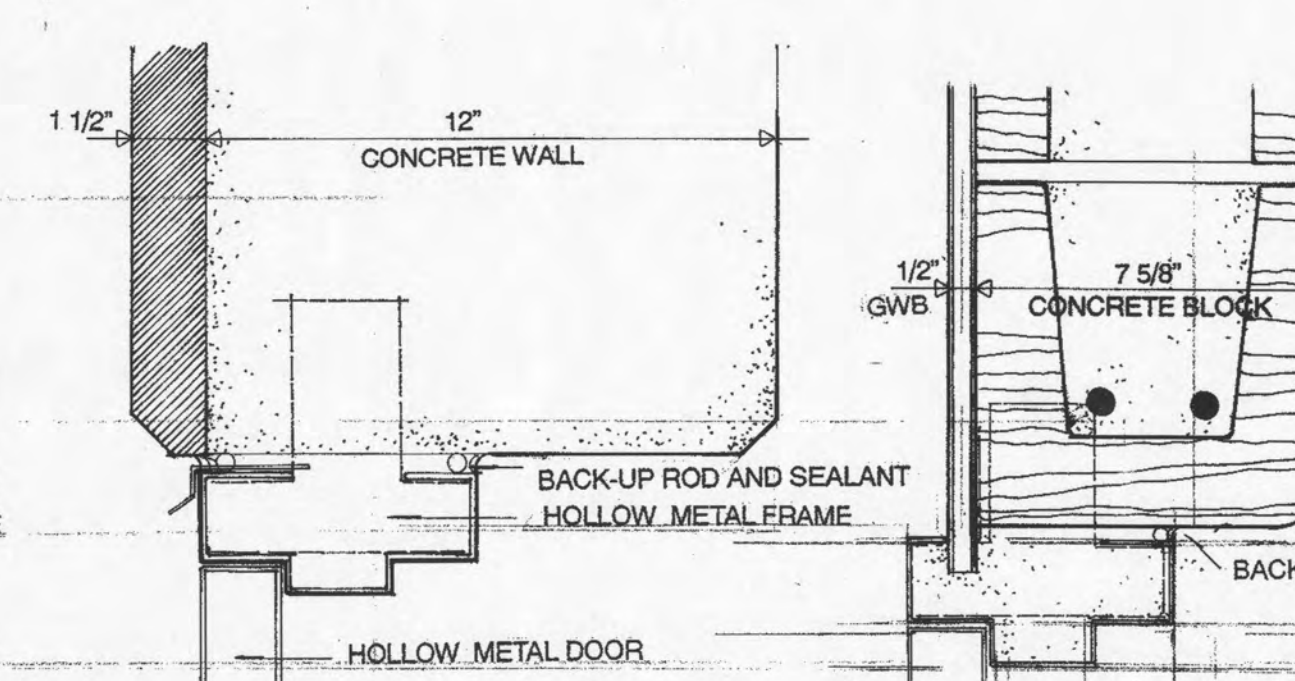

23 JAMB DETAIL
A 24 SCALE 3"=1'-0"
@ DOOR # 116A

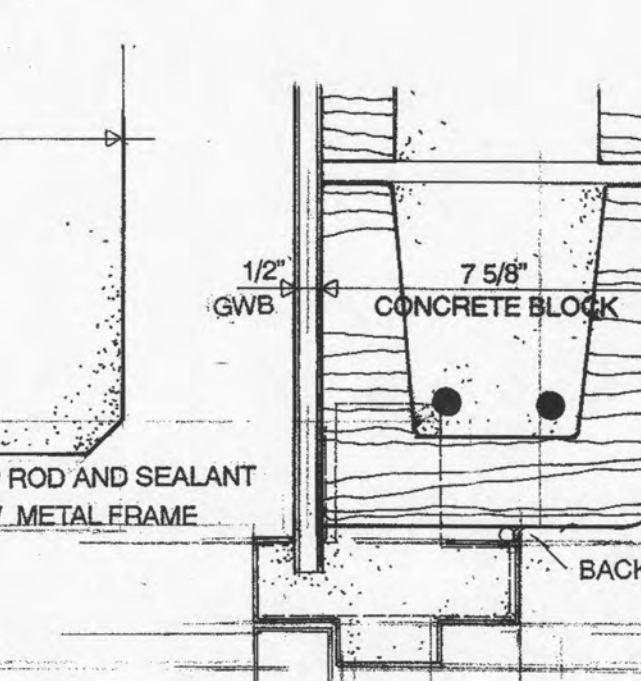


24 HEAD DETAIL
A 24 SCALE 3"=1'-0"

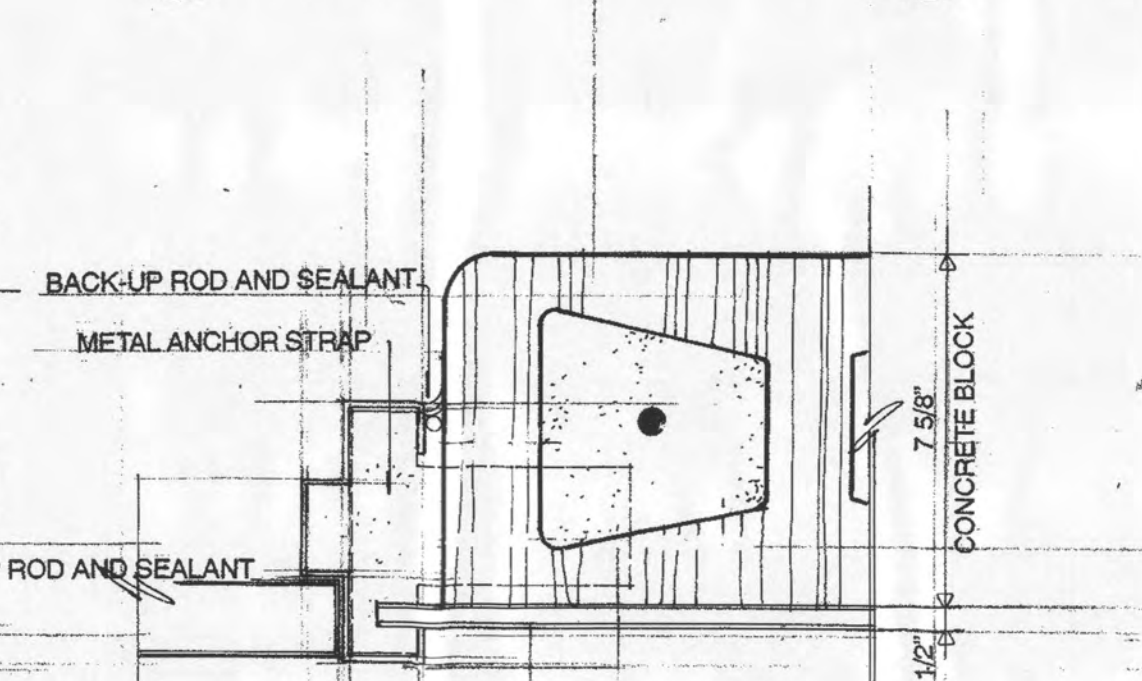


25 JAMB DETAIL
A 24 SCALE 3"=1'-0"



26 SILL DETAIL
A 24 SCALE 3"=1'-0"

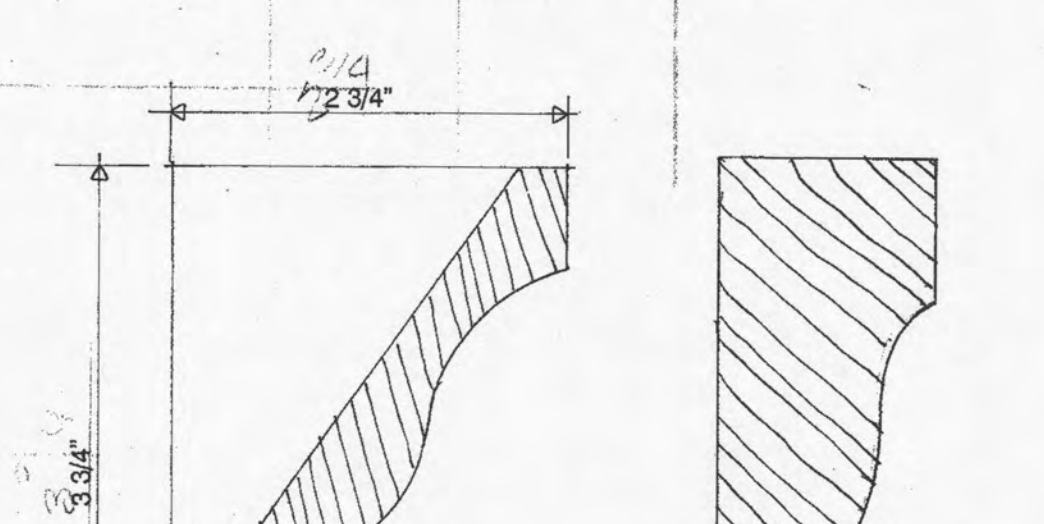


27 SILL DETAIL
A 24 SCALE 3"=1'-0"

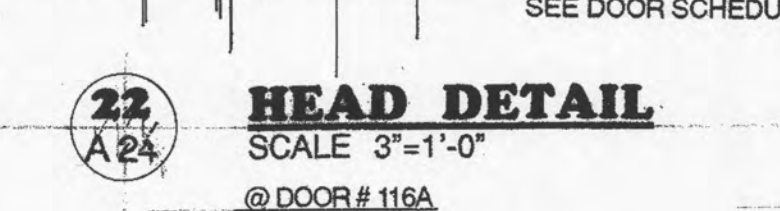


28 HEAD DETAIL
A 24 SCALE 3"=1'-0"



29 JAMB DETAIL
A 24 SCALE 3"=1'-0"

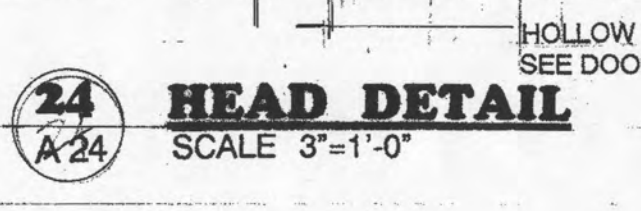


30 HEAD DETAIL
A 24 SCALE 3"=1'-0"

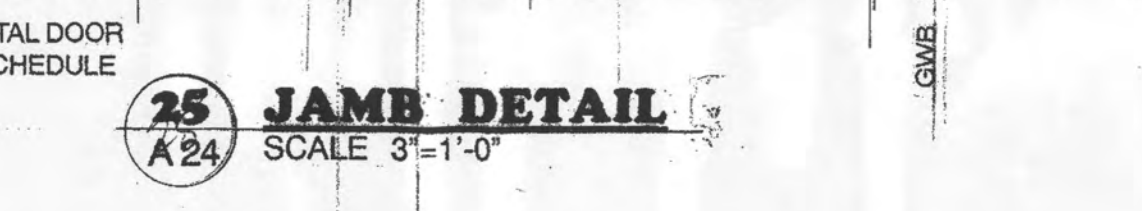


31 JAMB DETAIL
A 24 SCALE 3"=1'-0"



32 SILL DETAIL
A 24 SCALE 3"=1'-0"

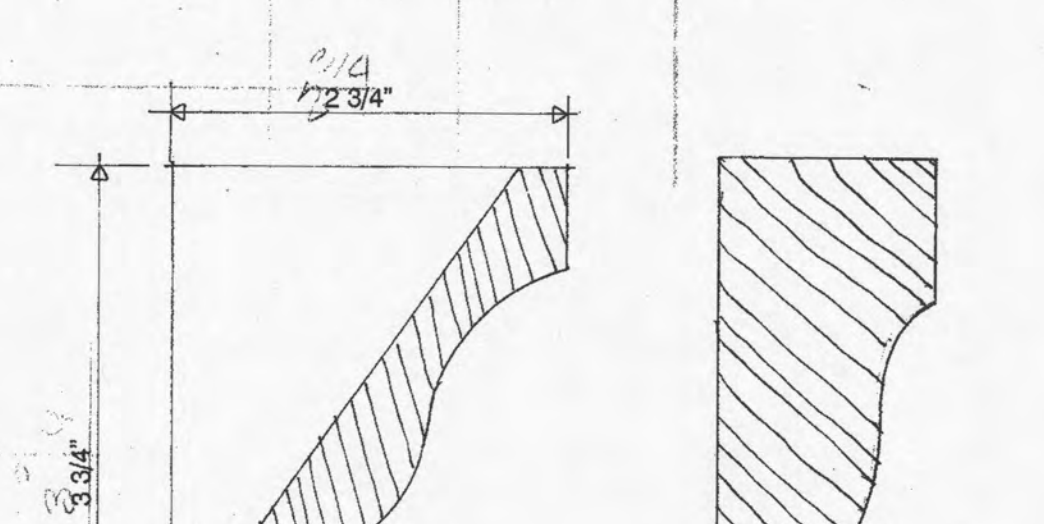

33 SILL DETAIL
A 24 SCALE 3"=1'-0"

 

34 HEAD DETAIL
A 24 SCALE 3"=1'-0"



35 JAMB DETAIL
A 24 SCALE 3"=1'-0"




36 HEAD DETAIL
A 24 SCALE 3"=1'-0"




37 JAMB DETAIL
A 24 SCALE 3"=1'-0"



38 SILL DETAIL
A 24 SCALE 3"=1'-0"

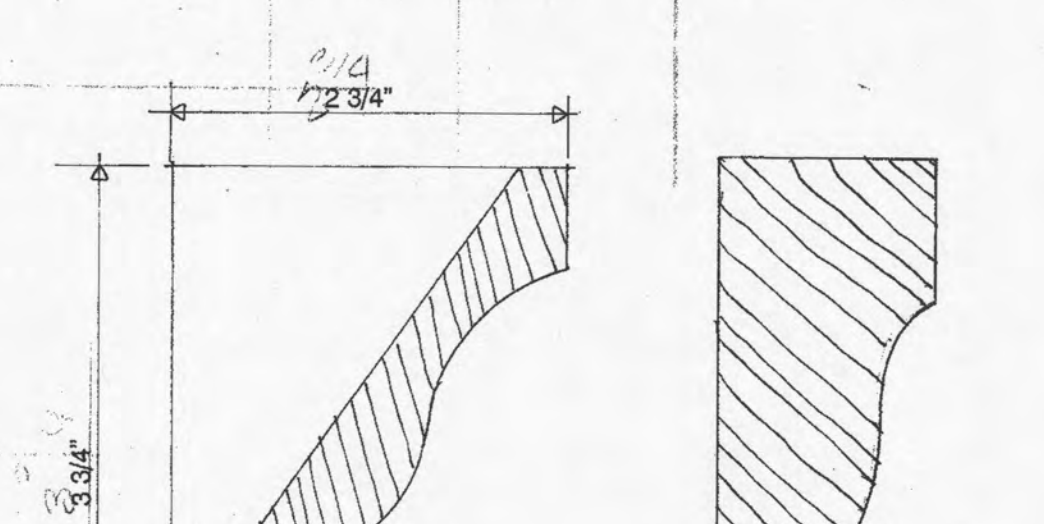

39 SILL DETAIL
A 24 SCALE 3"=1'-0"

 

40 HEAD DETAIL
A 24 SCALE 3"=1'-0"



41 JAMB DETAIL
A 24 SCALE 3"=1'-0"




42 HEAD DETAIL
A 24 SCALE 3"=1'-0"



43 JAMB DETAIL
A 24 SCALE 3"=1'-0"



44 SILL DETAIL
A 24 SCALE 3"=1'-0"

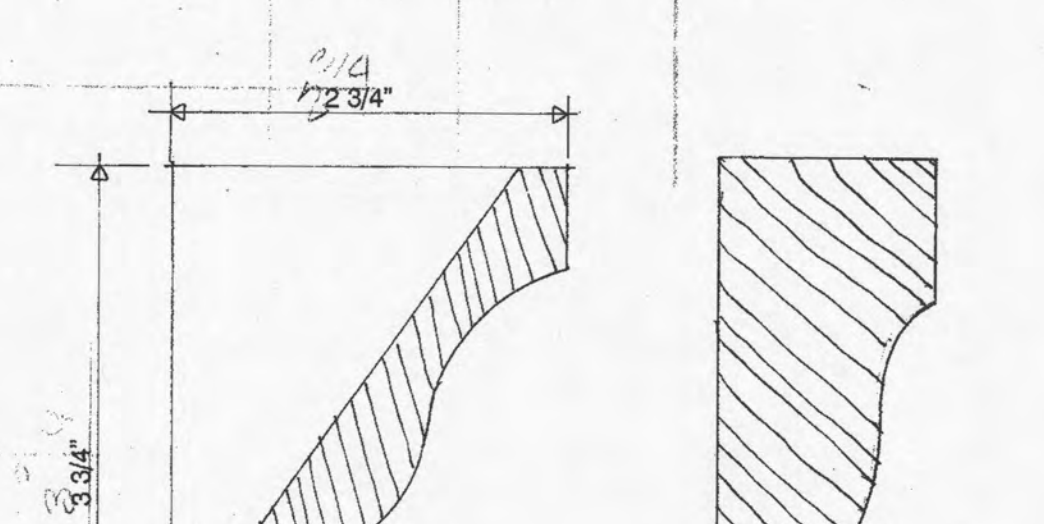

45 SILL DETAIL
A 24 SCALE 3"=1'-0"



46 HEAD DETAIL
A 24 SCALE 3"=1'-0"



47 JAMB DETAIL
A 24 SCALE 3"=1'-0"




48 HEAD DETAIL
A 24 SCALE 3"=1'-0"



49 JAMB DETAIL
A 24 SCALE 3"=1'-0"



50 SILL DETAIL
A 24 SCALE 3"=1'-0"

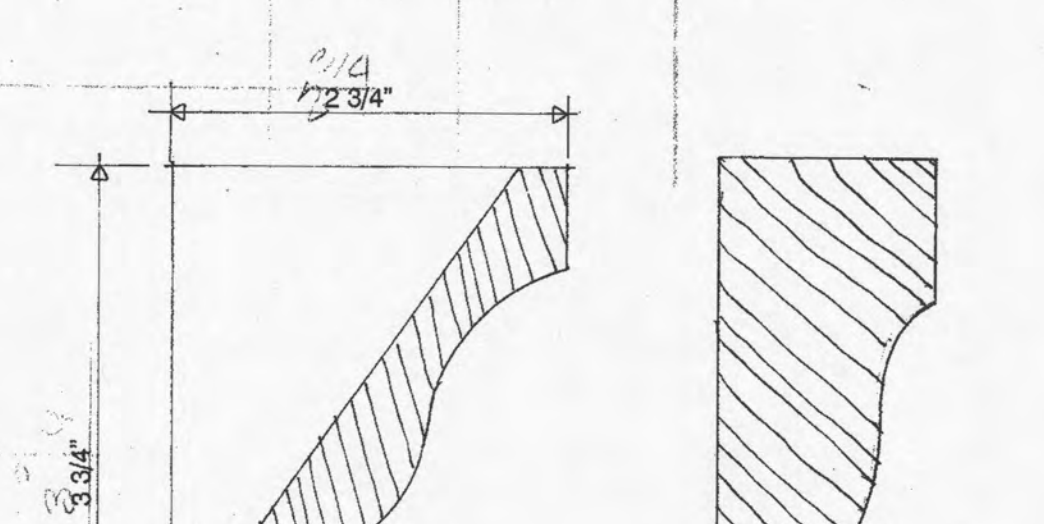

51 SILL DETAIL
A 24 SCALE 3"=1'-0"

52 HEAD DETAIL
A 24 SCALE 3"=1'-0"


53 JAMB DETAIL
A 24 SCALE 3"=1'-0"

54 HEAD DETAIL
A 24 SCALE 3"=1'-0"

55 JAMB DETAIL
A 24 SCALE 3"=1'-0"



56 SILL DETAIL
A 24 SCALE 3"=1'-0"

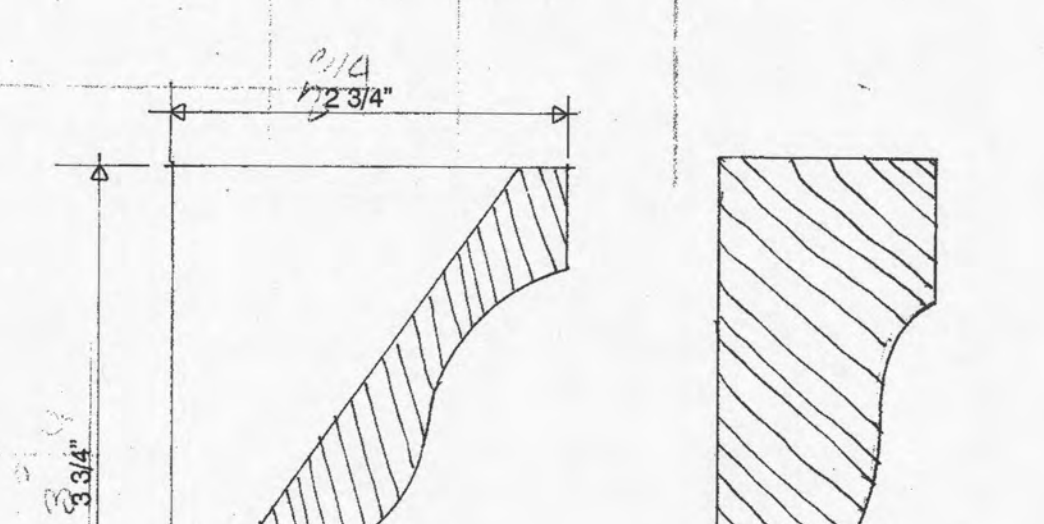

57 SILL DETAIL
A 24 SCALE 3"=1'-0"

58 HEAD DETAIL
A 24 SCALE 3"=1'-0"


59 JAMB DETAIL
A 24 SCALE 3"=1'-0"

60 HEAD DETAIL
A 24 SCALE 3"=1'-0"

61 JAMB DETAIL
A 24 SCALE 3"=1'-0"



62 SILL DETAIL
A 24 SCALE 3"=1'-0"

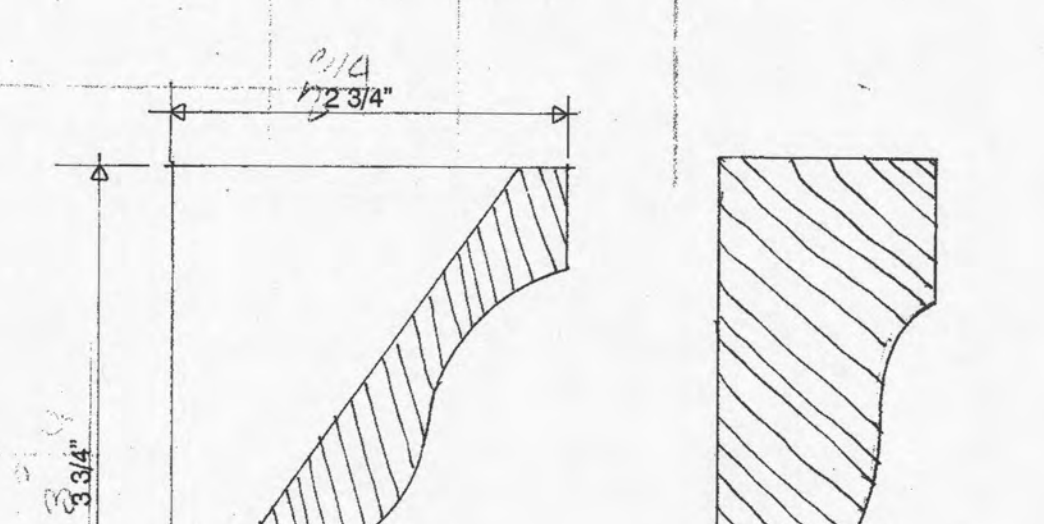

63 SILL DETAIL
A 24 SCALE 3"=1'-0"

64 HEAD DETAIL
A 24 SCALE 3"=1'-0"

65 JAMB DETAIL
A 24 SCALE 3"=1'-0"












66 HEAD DETAIL
A 24 SCALE 3"=1'-0"

67 JAMB DETAIL
A 24 SCALE 3"=1'-0"



MILLWORK PROFILES

SCALE: 3/4" = 1'-0"

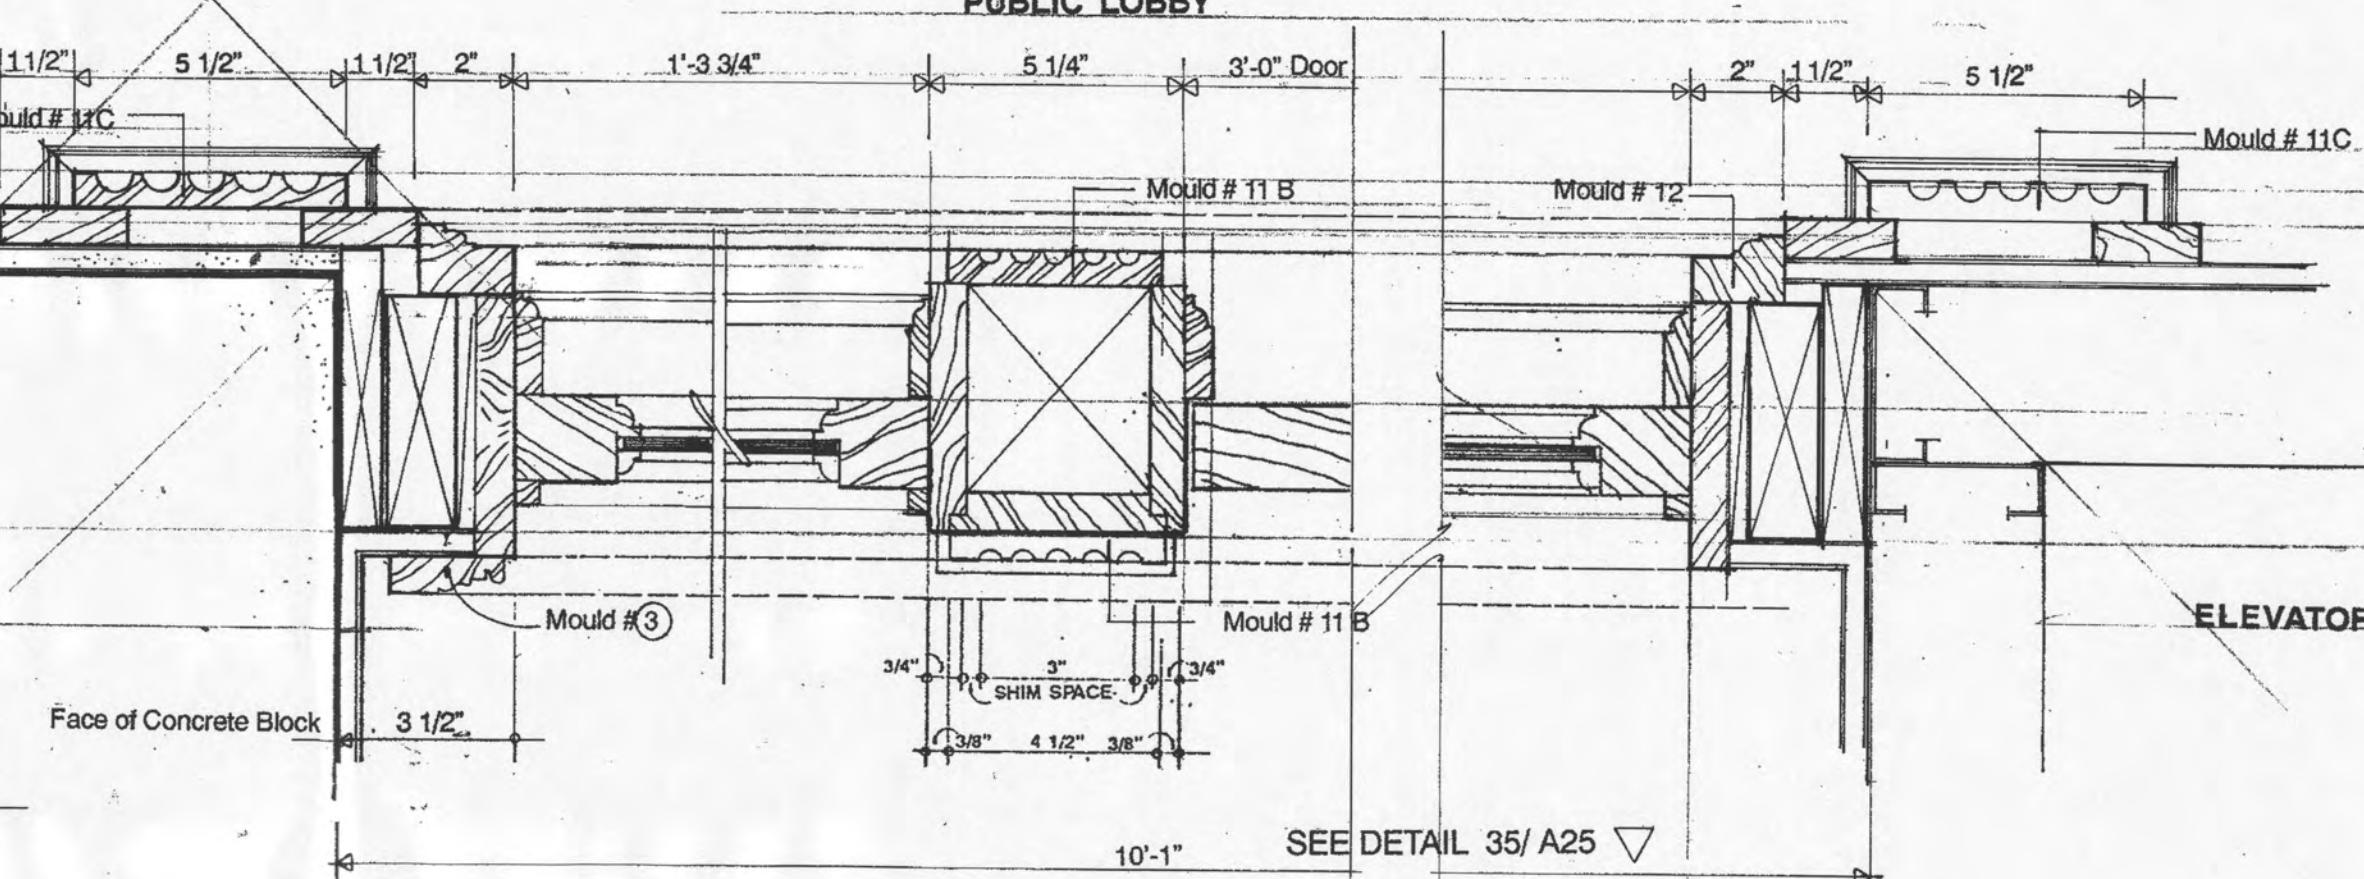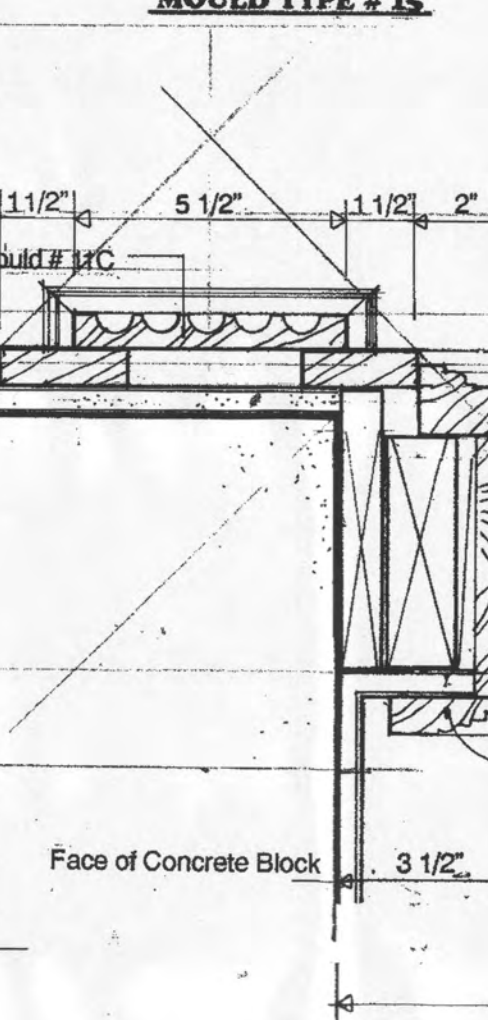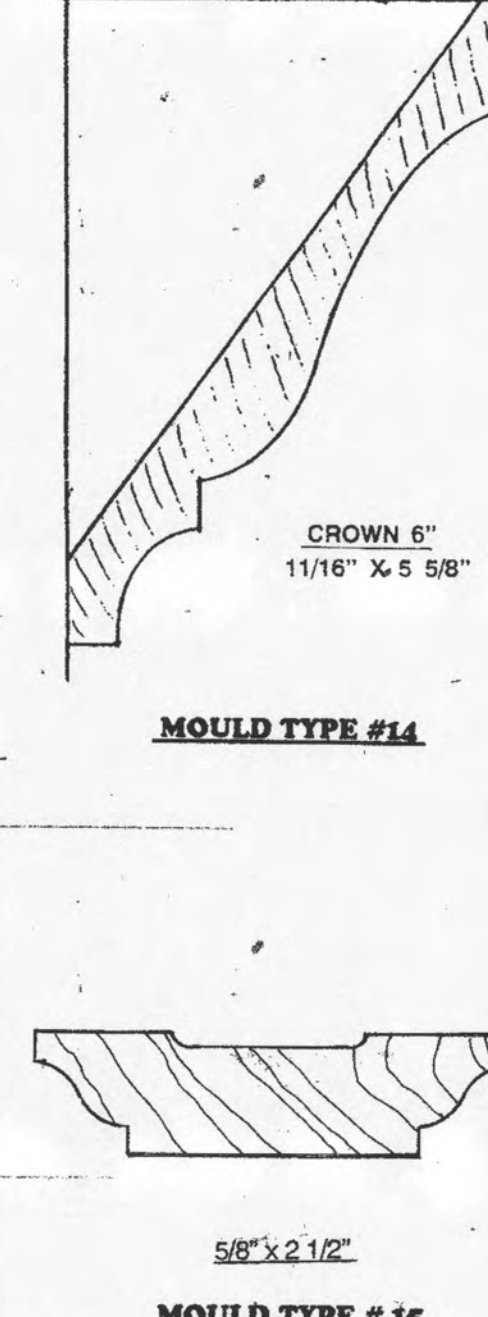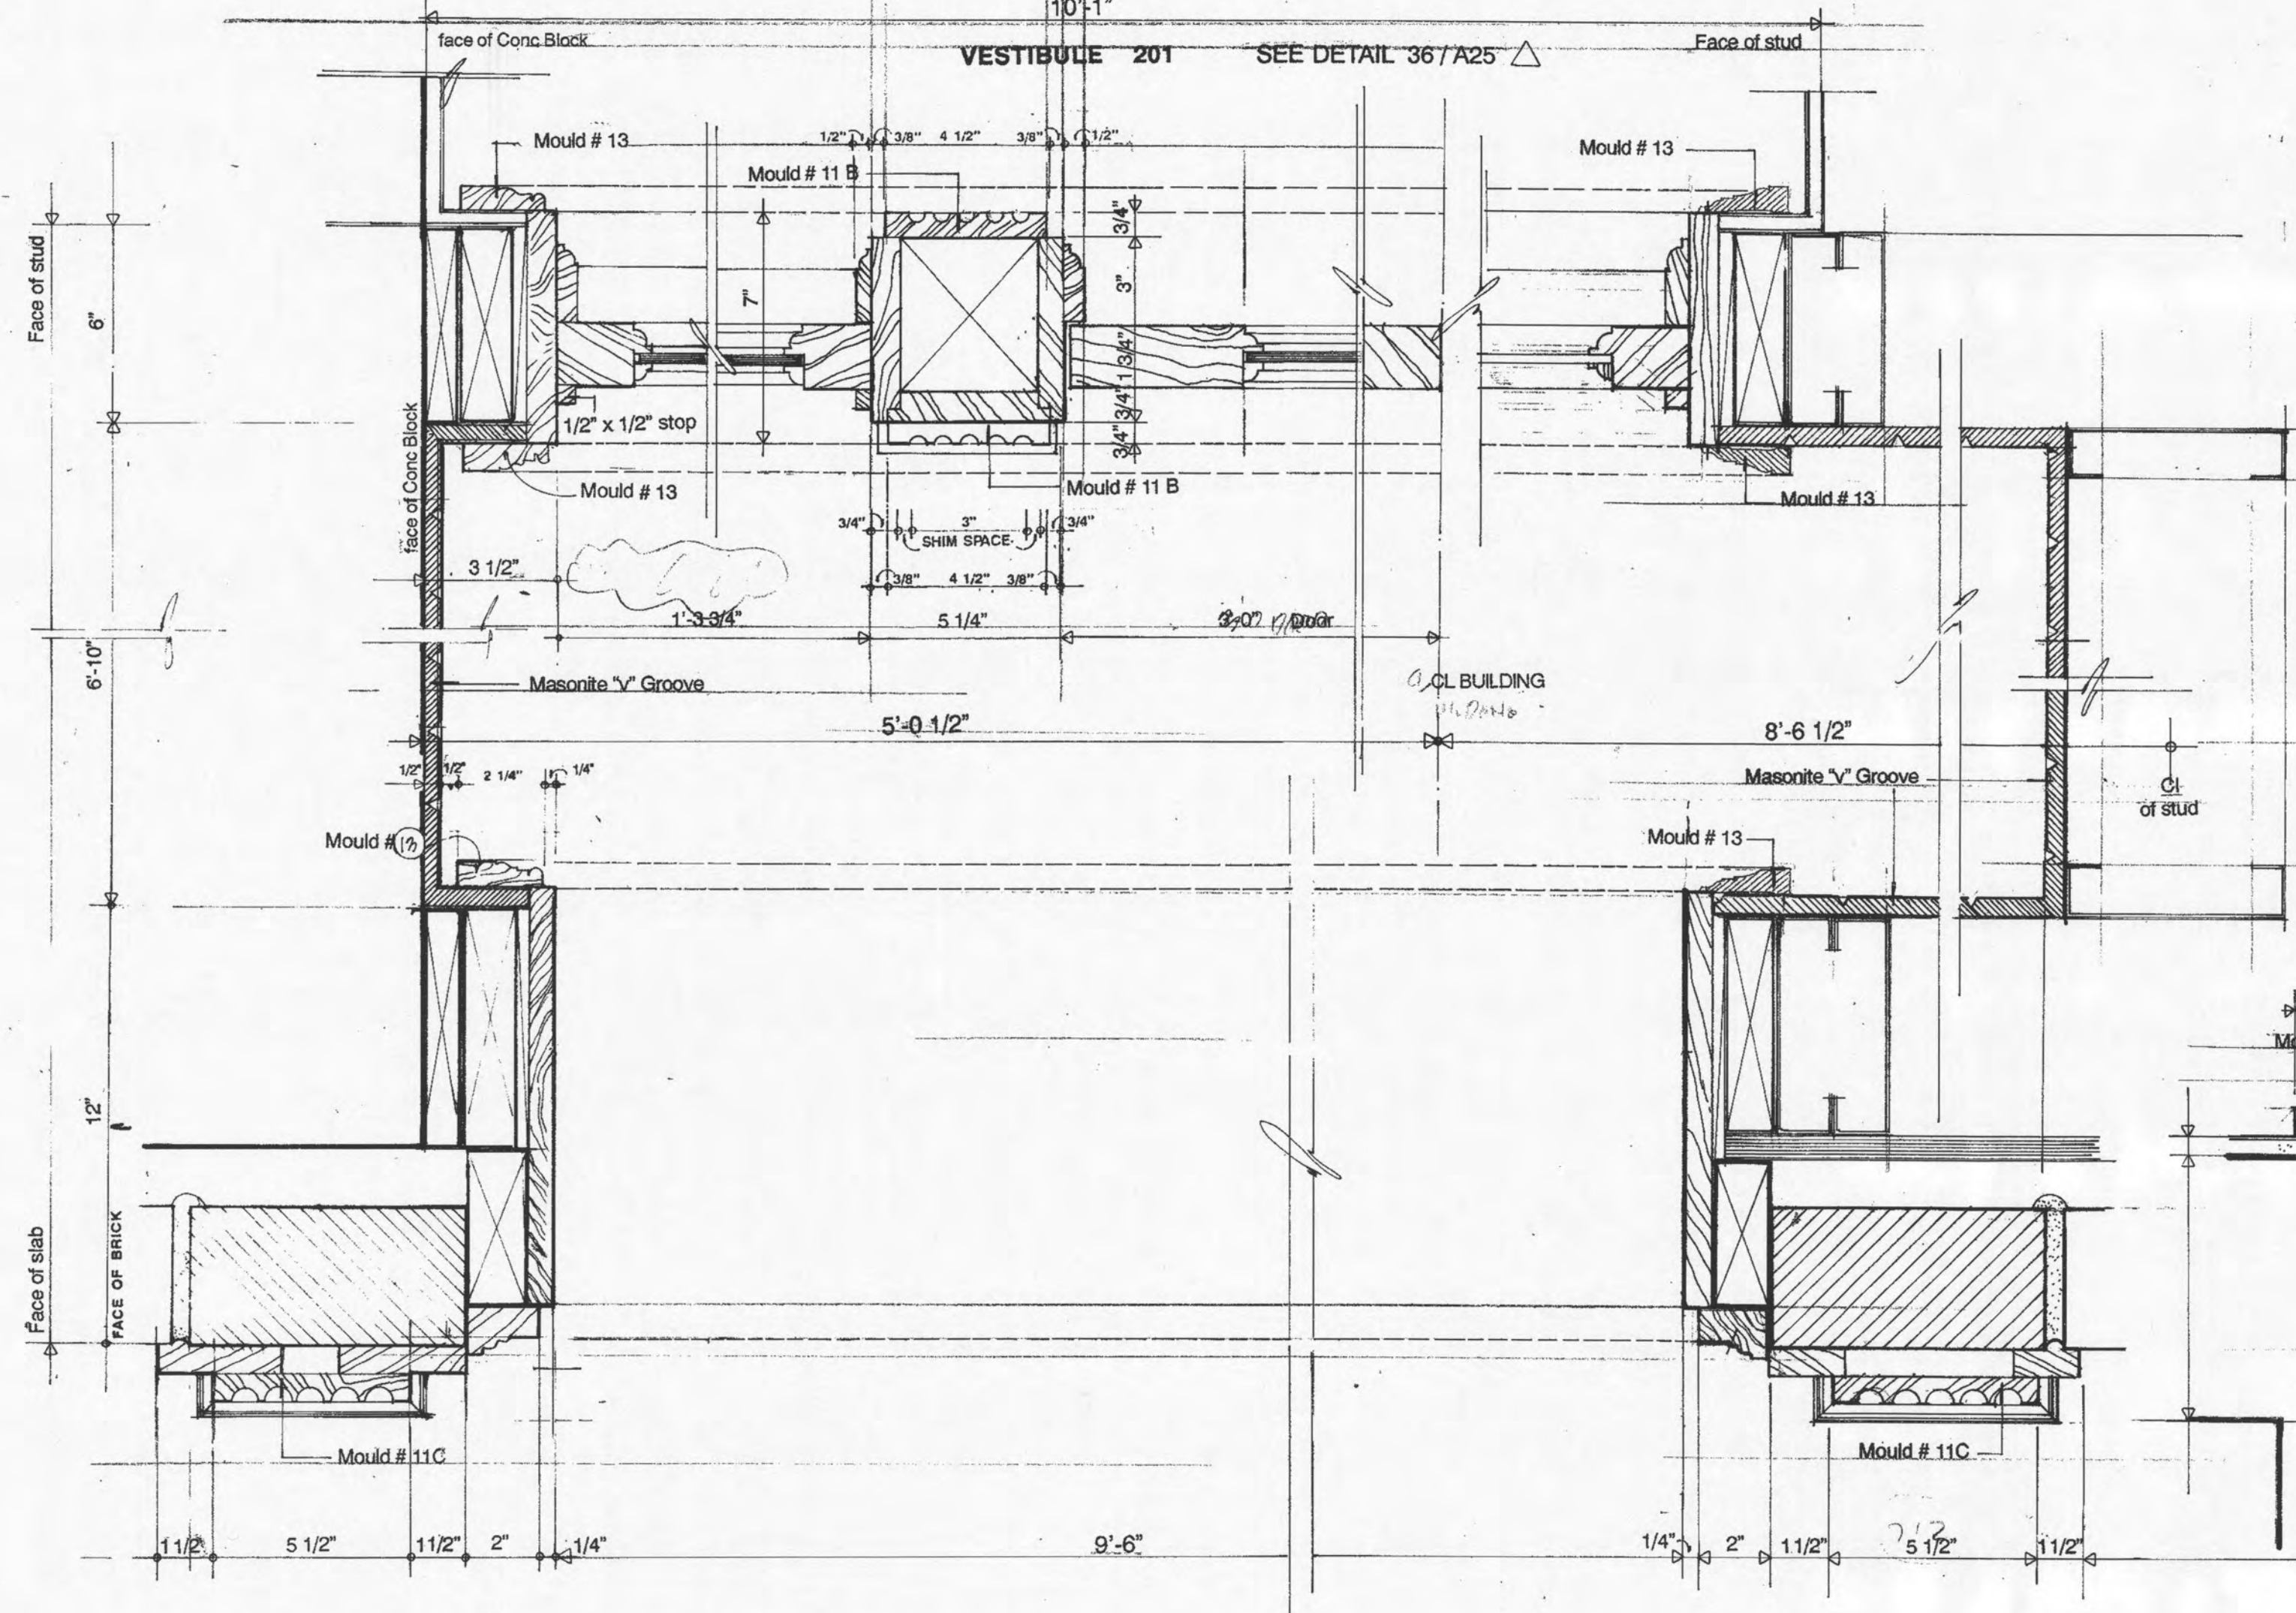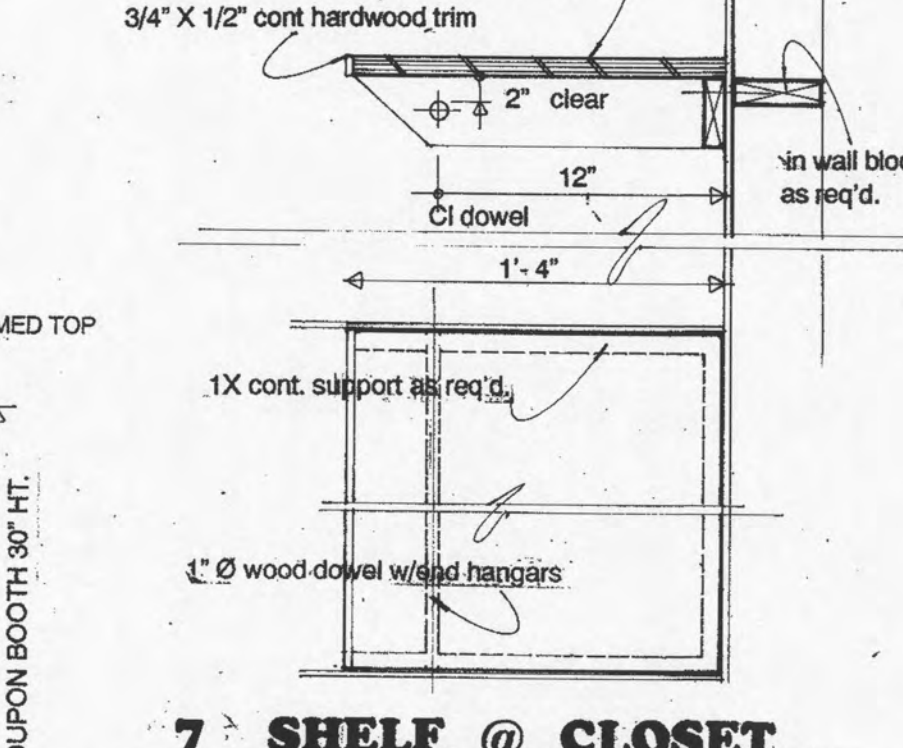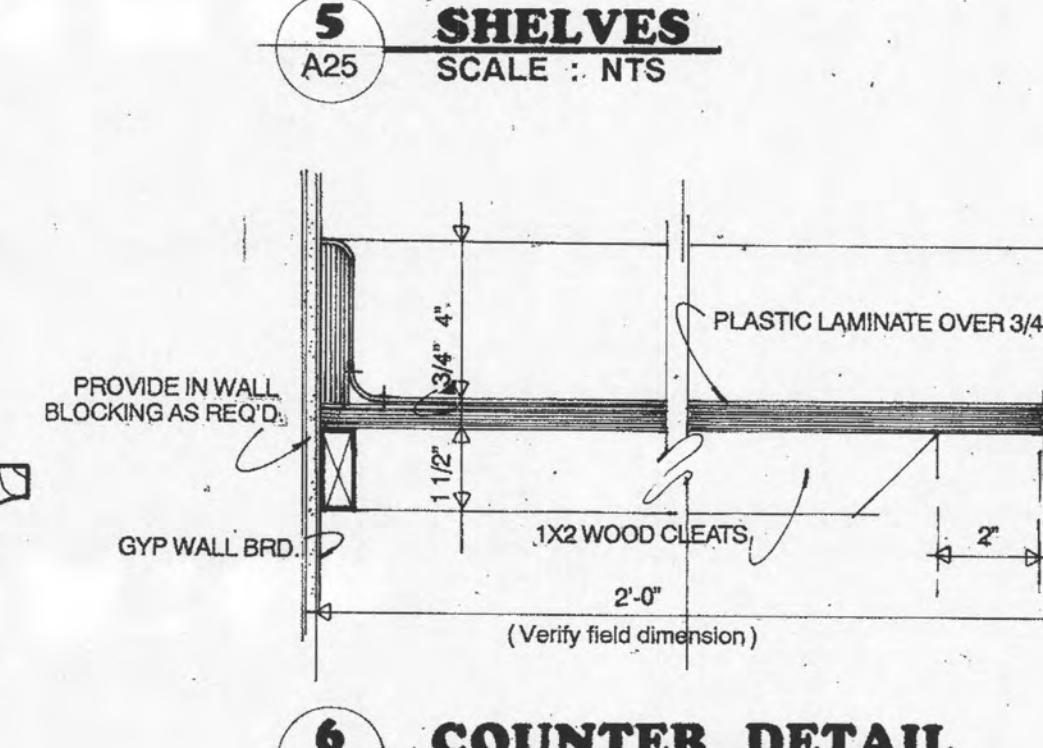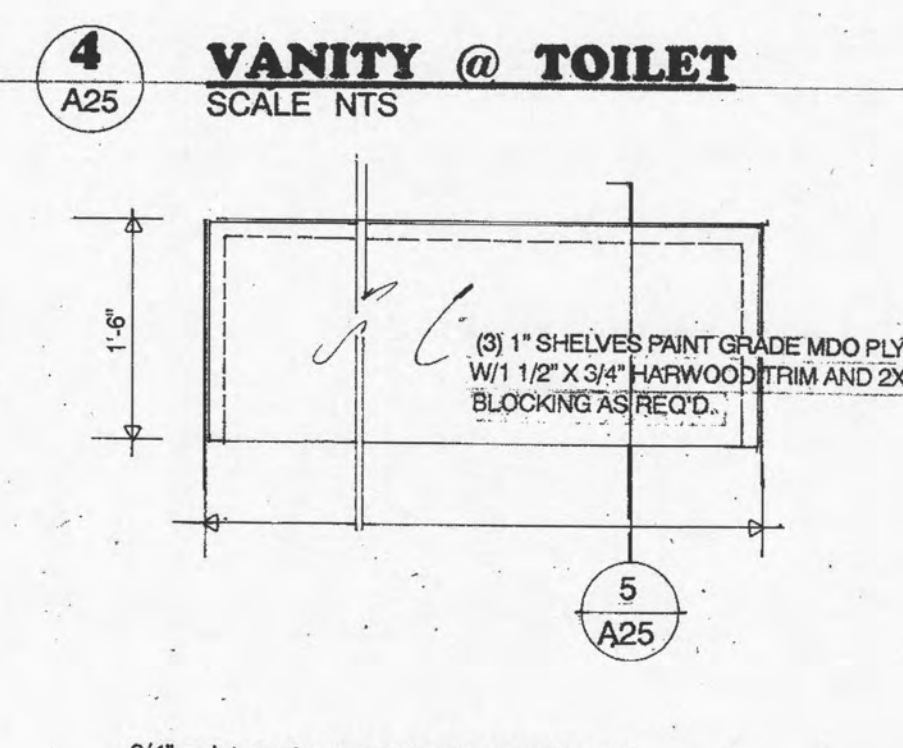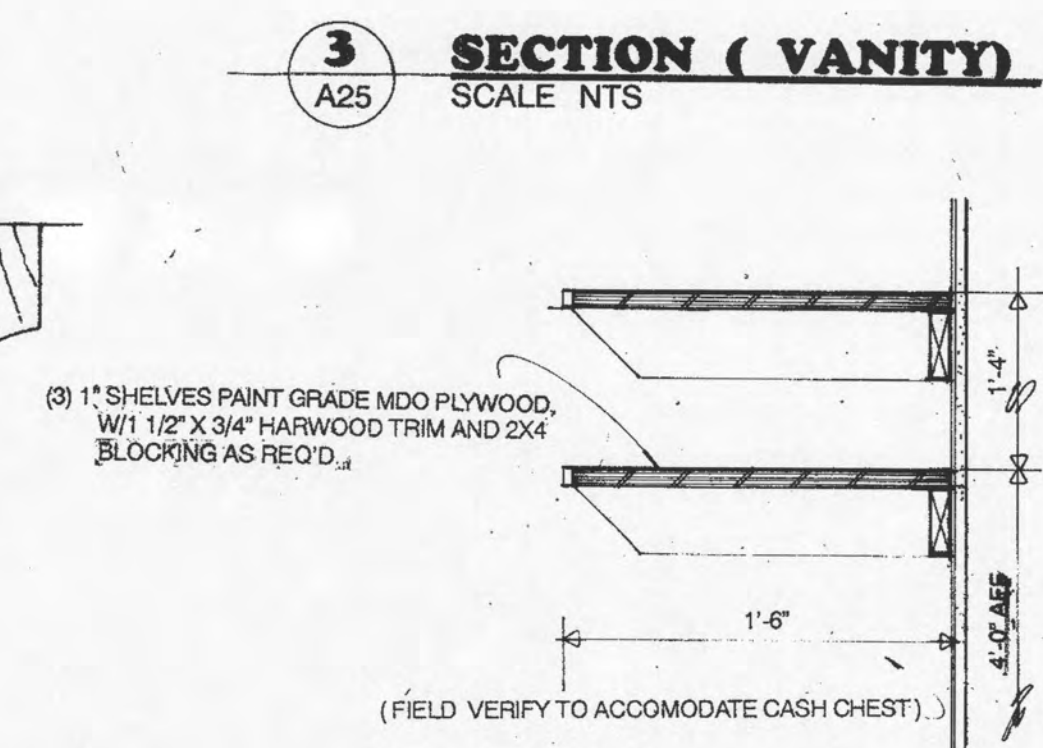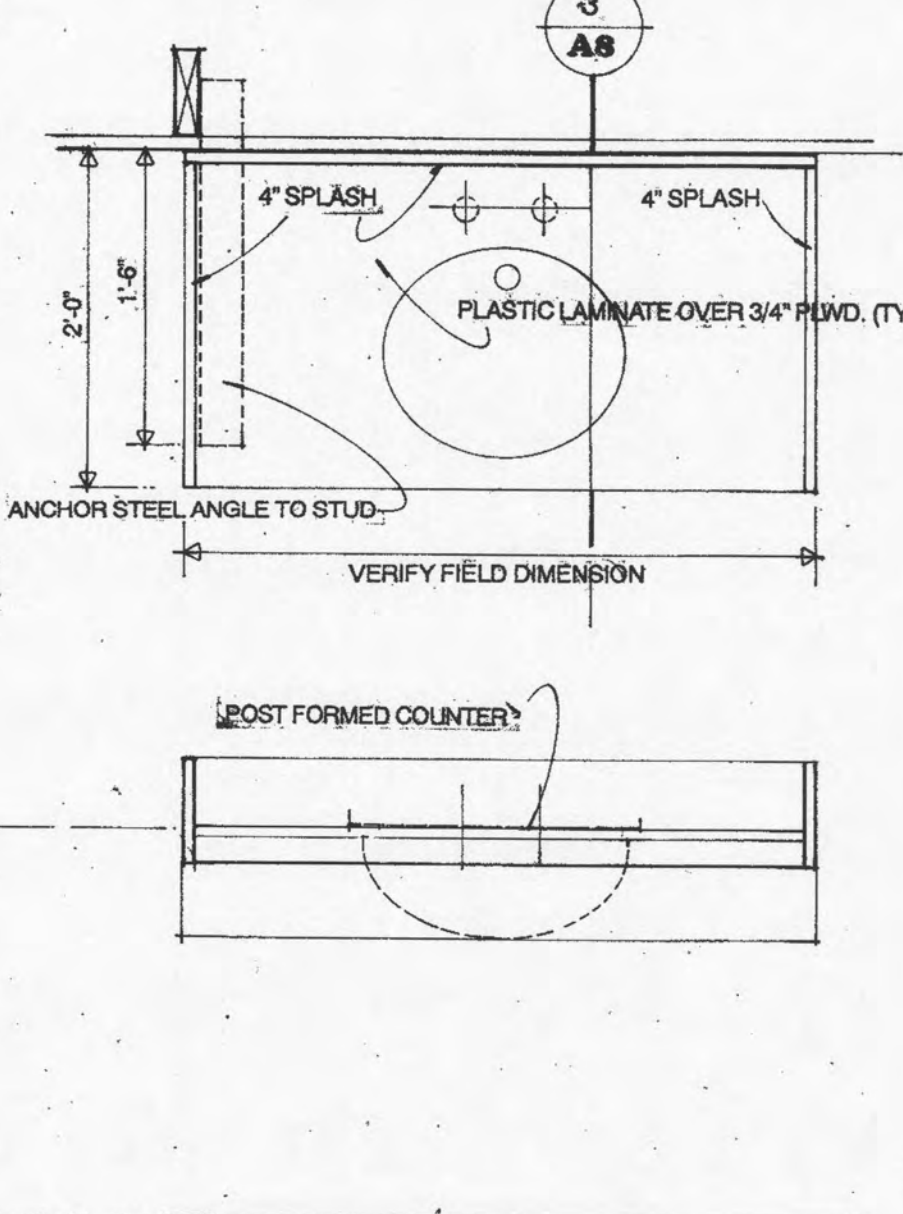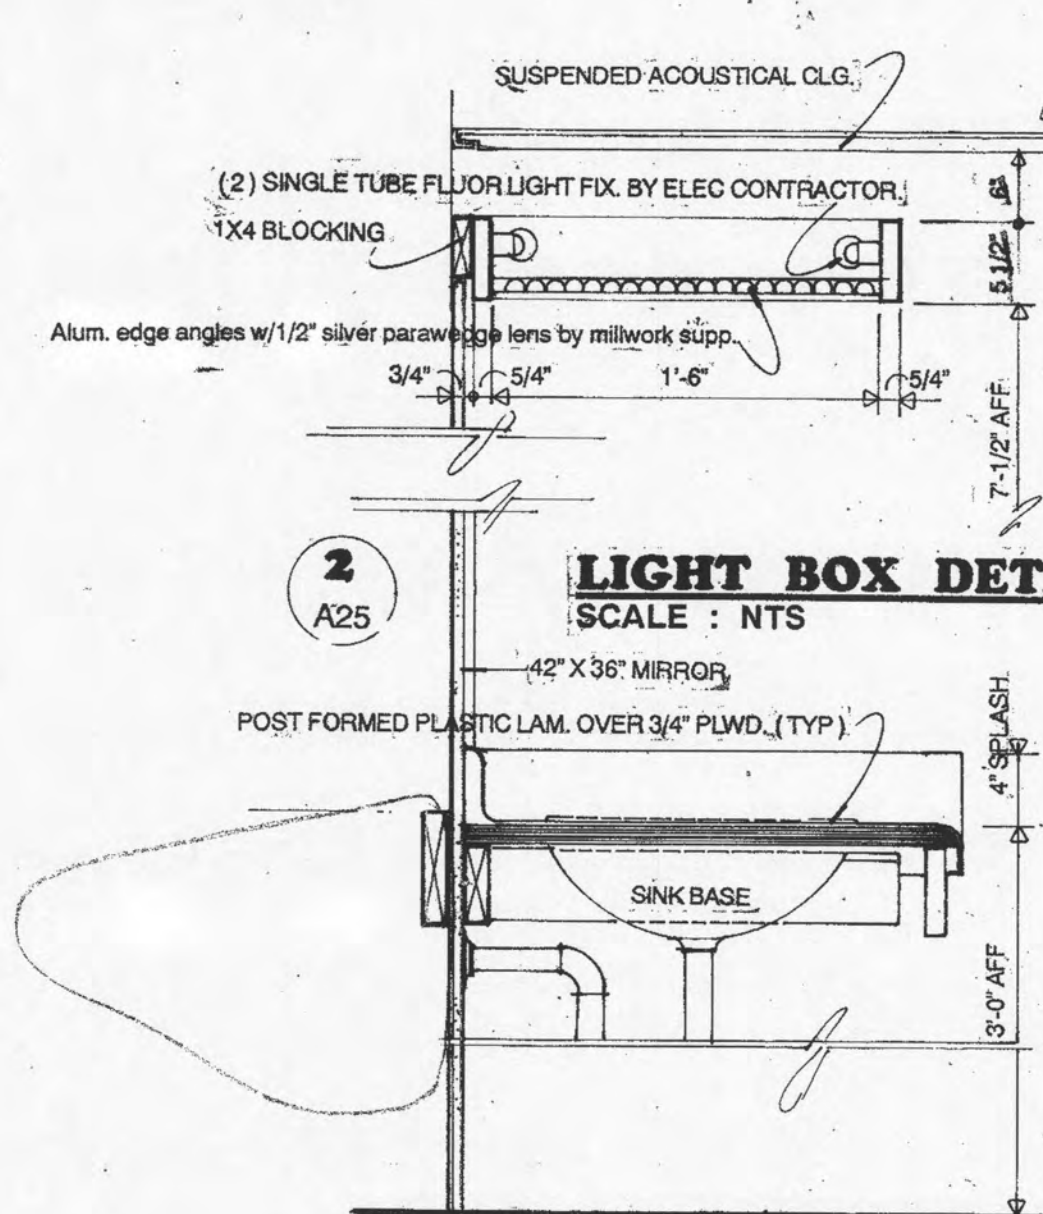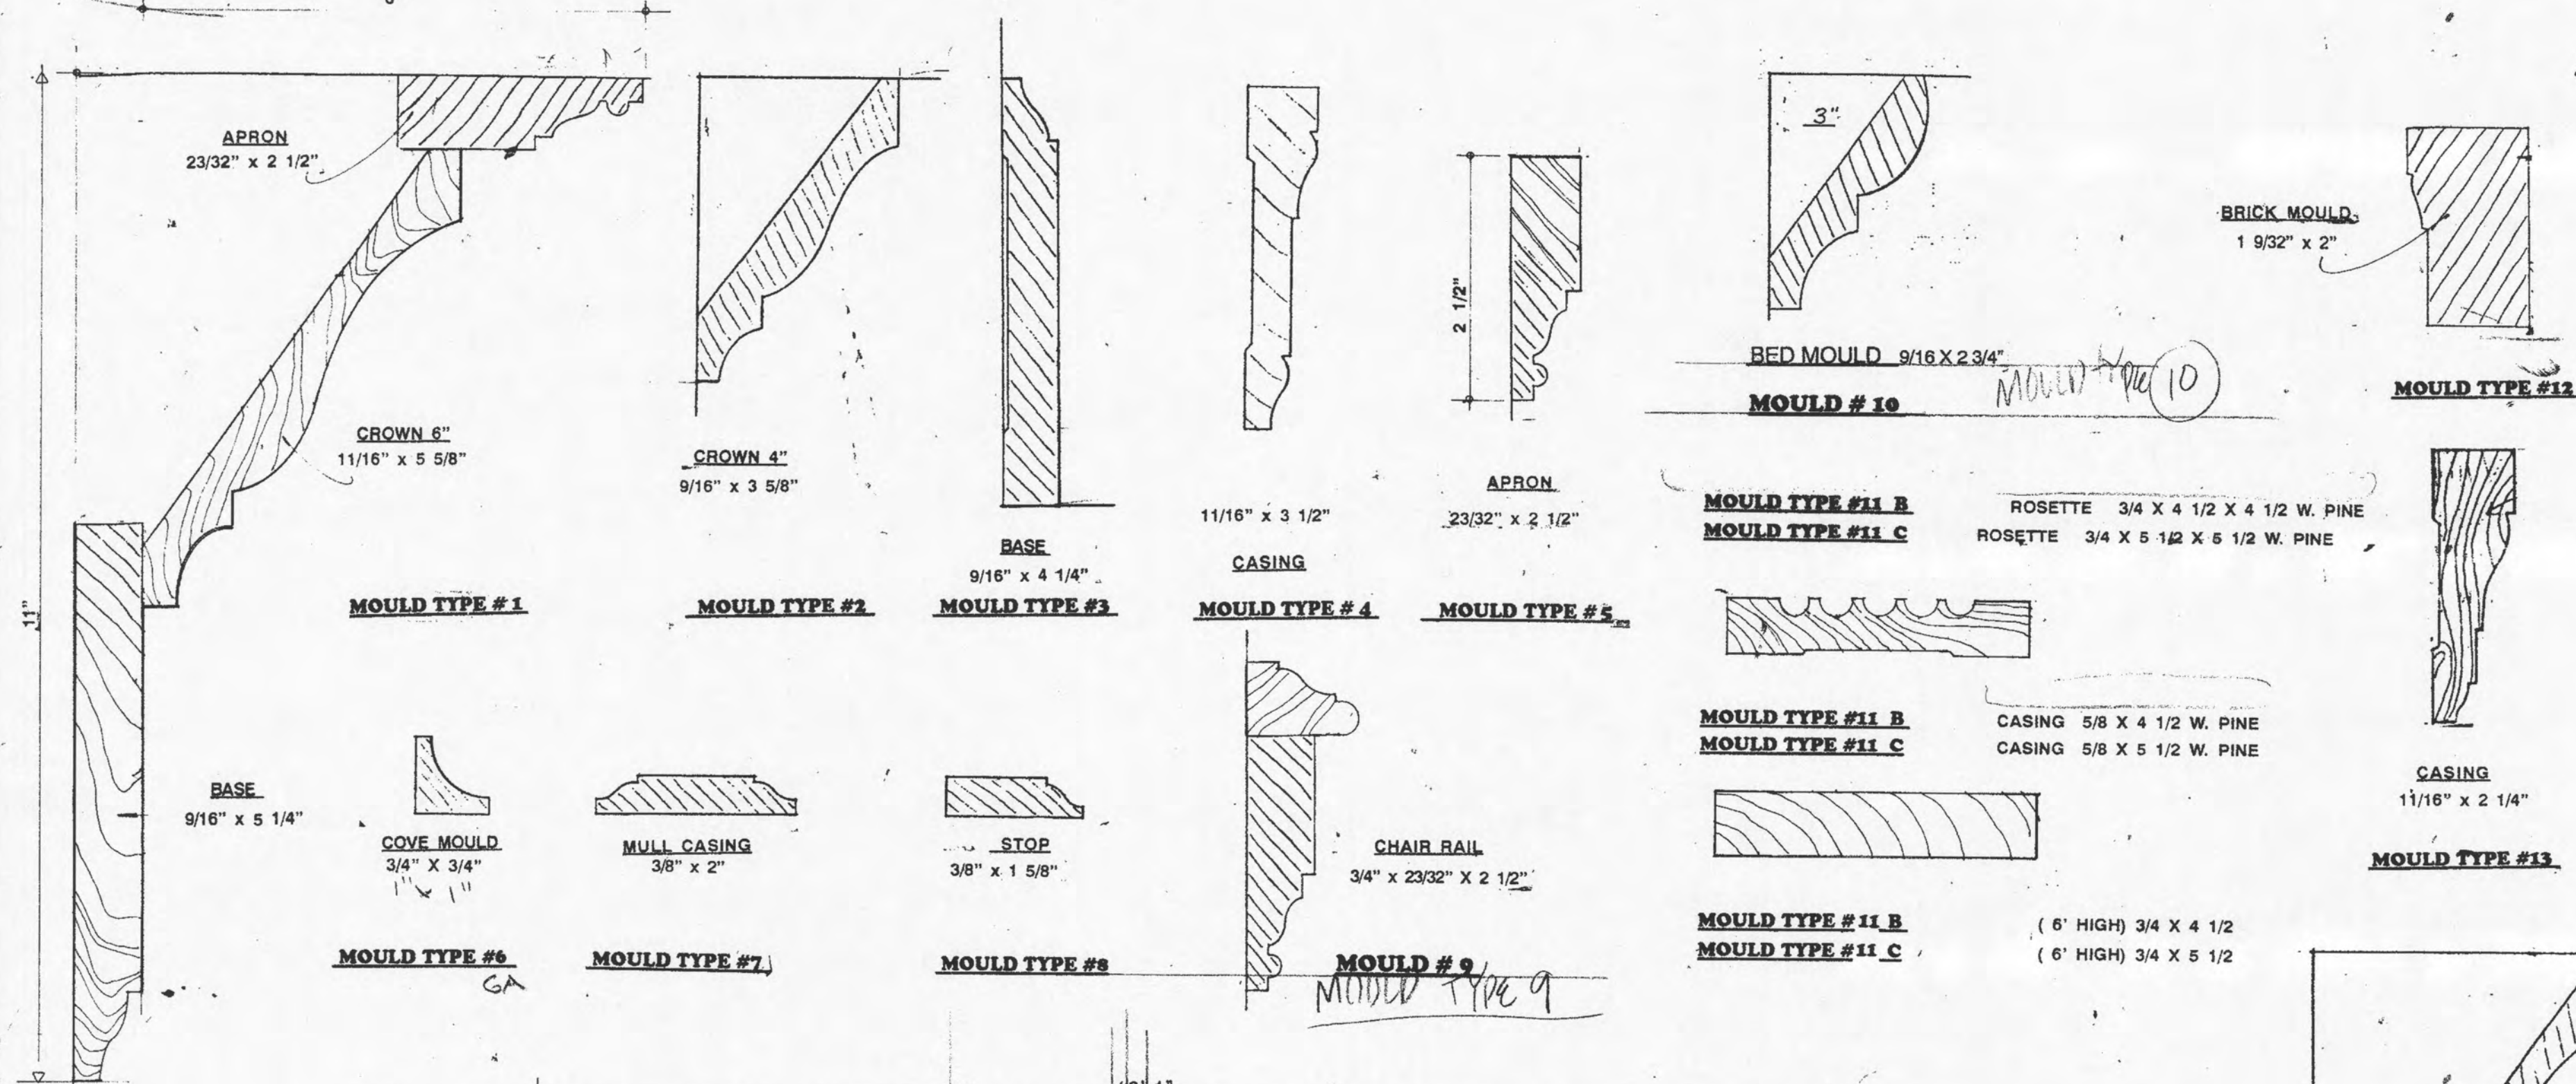

35 PLAN (JAMB) DETAIL
A25 SCALE: 3\"/>

36 PLAN (JAMB) DETAIL
A25 SCALE: 3\"/>

343

REVISED

DATE

BY

CK

REV

PRINT DATE

Consolidators

Designers

Construction Managers

RELEASED FOR CONSTRUCTION

The drawings and the design thereon are the sole property of the firm and shall not be reproduced or used in any manner without the written consent of the firm. Any unauthorized reproduction or use of these drawings is prohibited.

MILLWORK / PLAN DETAILS

A NEW MAIN OFFICE FACILITIES FOR:


Bank of Roane County

HARRIMAN, TENNESSEE


SEP. 10, 1992

A-25


of 28 sheets

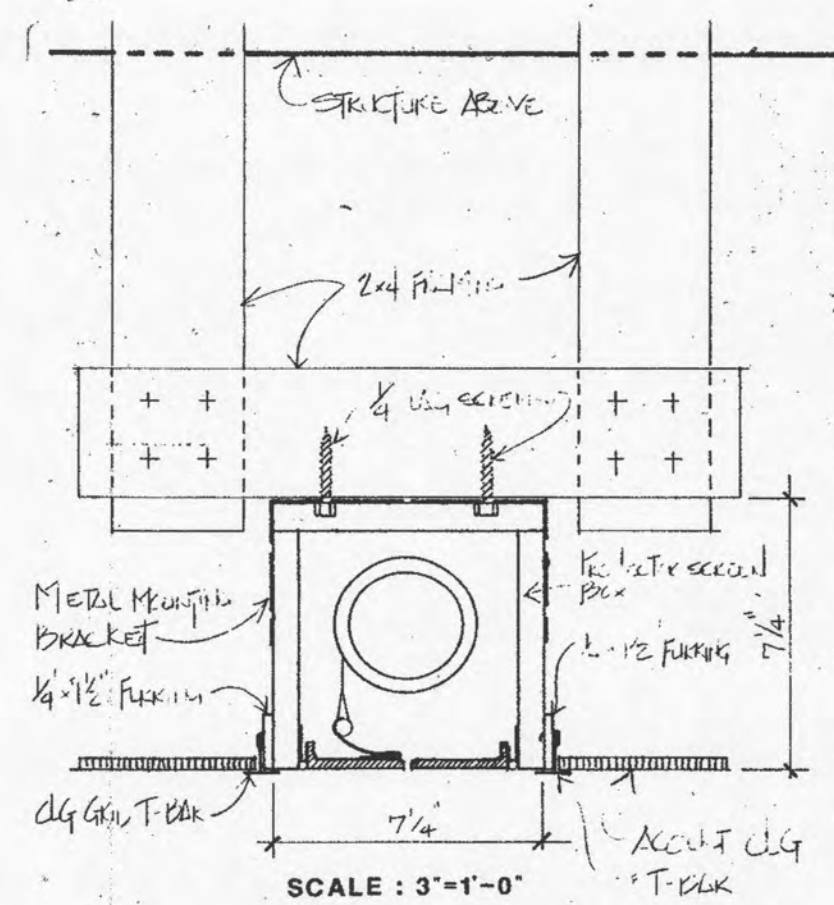


1 PROJECTION SCREEN DETAIL
A-26 N.T.S.

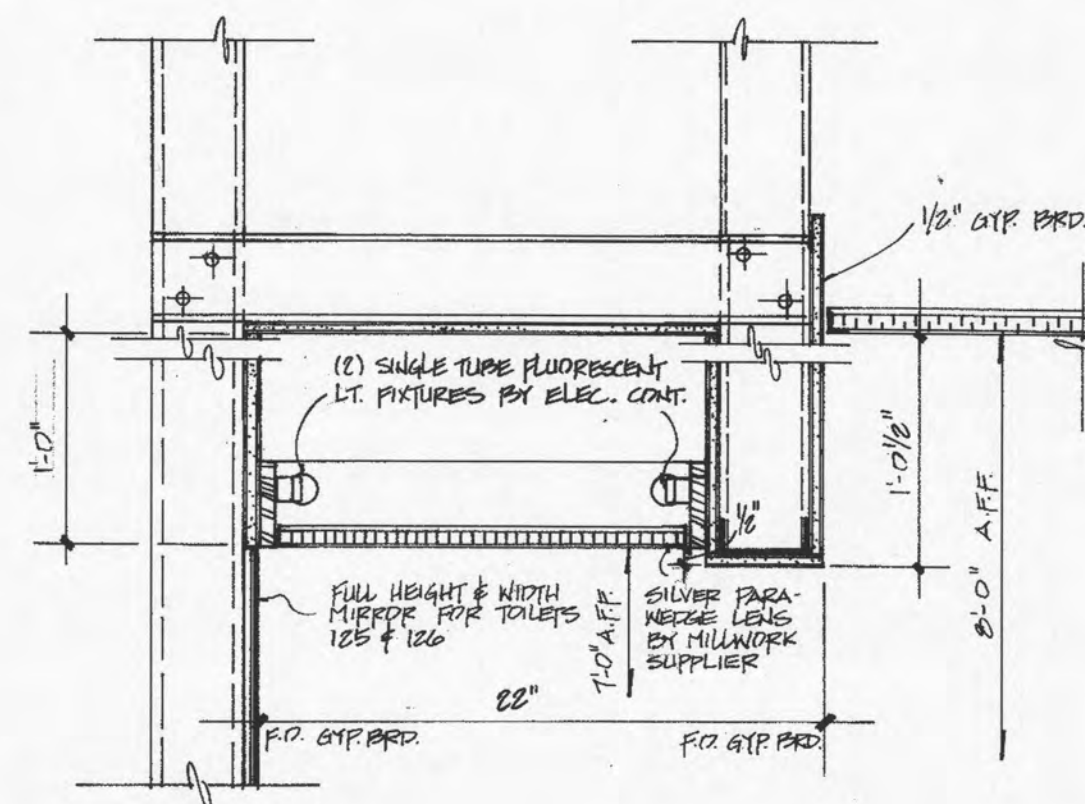


2 LIGHT BOX DETAIL
A-26 SCALE: 1 1/2" = 1'-0"

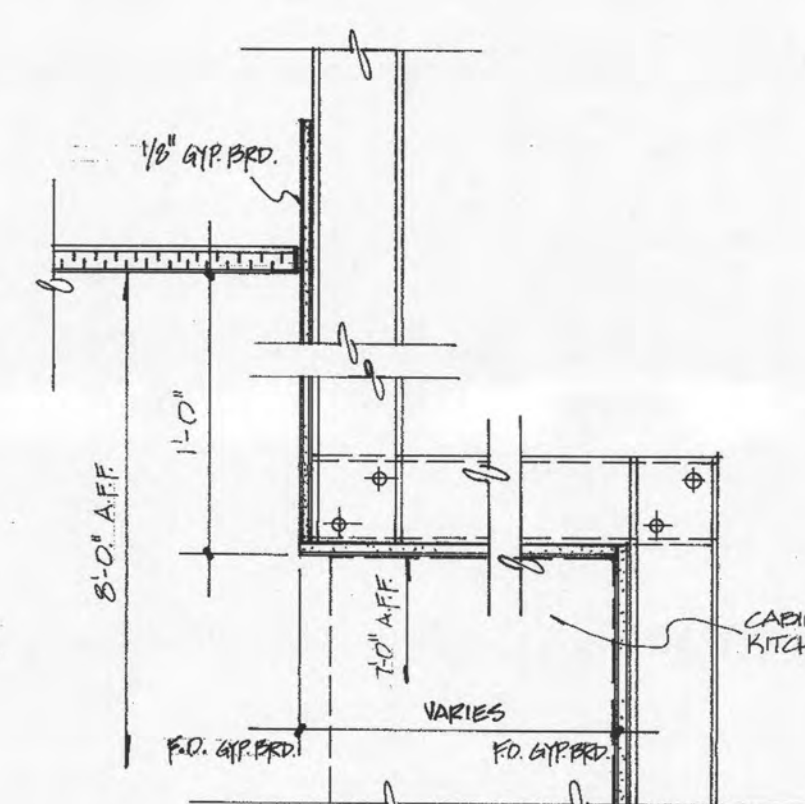

3 CEILING DETAIL
A-26 SCALE: 1 1/2" = 1'-0"

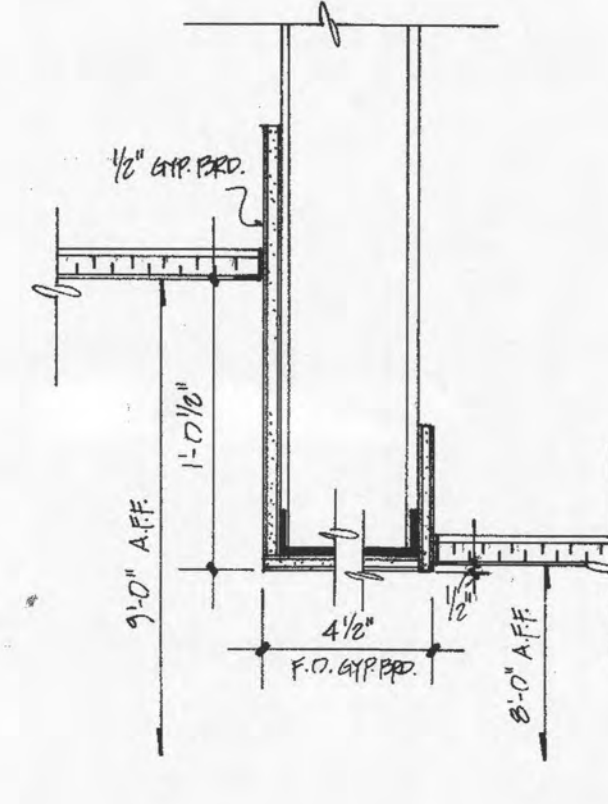

4 CEILING DETAIL
A-26 SCALE: 1 1/2" = 1'-0"

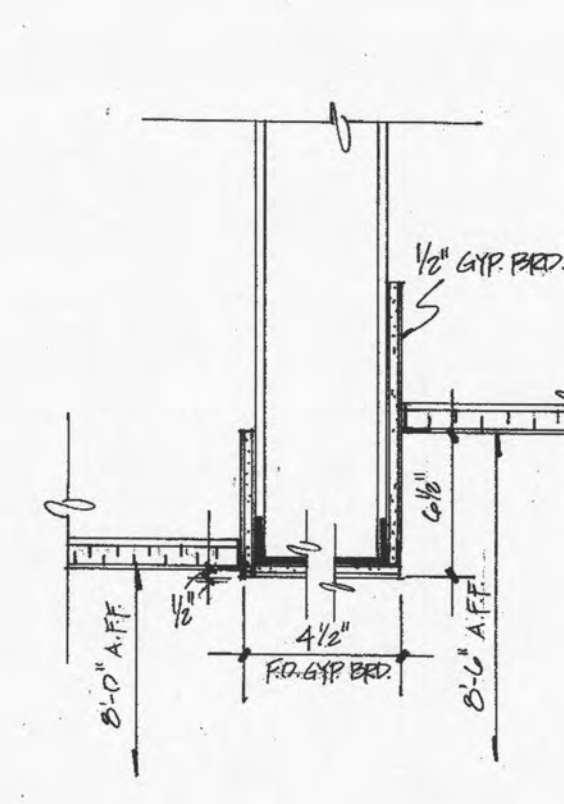

5 CEILING DETAIL
A-26 SCALE: 1 1/2" = 1'-0"


REFLECTED CEILING PLAN LEGEND

1. 24" x 24" x 3/4" LAY-IN ACOUSTICAL SUSPENDED CEILING TILE.
2. 24" x 48" x 3/4" LAY-IN ACOUSTICAL SUSPENDED CEILING TILE.
3. 24" x 48" LAY-IN FLUORESCENT LIGHT FIXTURE - SEE SPECIFICATIONS FOR MANUFACTURER & TYPE.
4. HANGING CHANDELIER LOCATION - SEE SPECIFICATIONS FOR MANUFACTURER & TYPE.
5. PAINT GRADE WOOD CROWN MOULD - SEE CEILING DETAILS FOR PROFILE.
6. 4" - 1" GROOVE MASONITE CEILING AND WALL PANELS.
7. SUPPLY AIR DIFFUSER
8. RETURN AIR GRILLE
9. RECESSED ADJUSTABLE DOWNLIGHT
10. RECESSED DOWNLIGHT

NOTE: SEE SPECIFICATIONS FOR CEILING TILE MNFR. & TYPES.

ELECTRICAL SYMBOLS



1. WALL MOUNTED LIGHT FIXTURE
2. WALL WASHER LIGHT FIXTURE
3. CEILING MOUNTED EXT LIGHT
4. WALL MOUNTED BATTERY OPERATED EMERGENCY LIGHT
5. CEILING MOUNTED REMOTE EMERGENCY LIGHT / 2 HEADS
6. CEILING MOUNTED REMOTE EMERGENCY LIGHT / 1 HEADS
7. SURFACE MTD. TRAFFIC LIGHT
8. RECESSED LIGHT FIXTURE METAL HALIDE.
9. 12"x48" SURFACE MOUNTED FLUORESCENT LIGHT FIXTURE

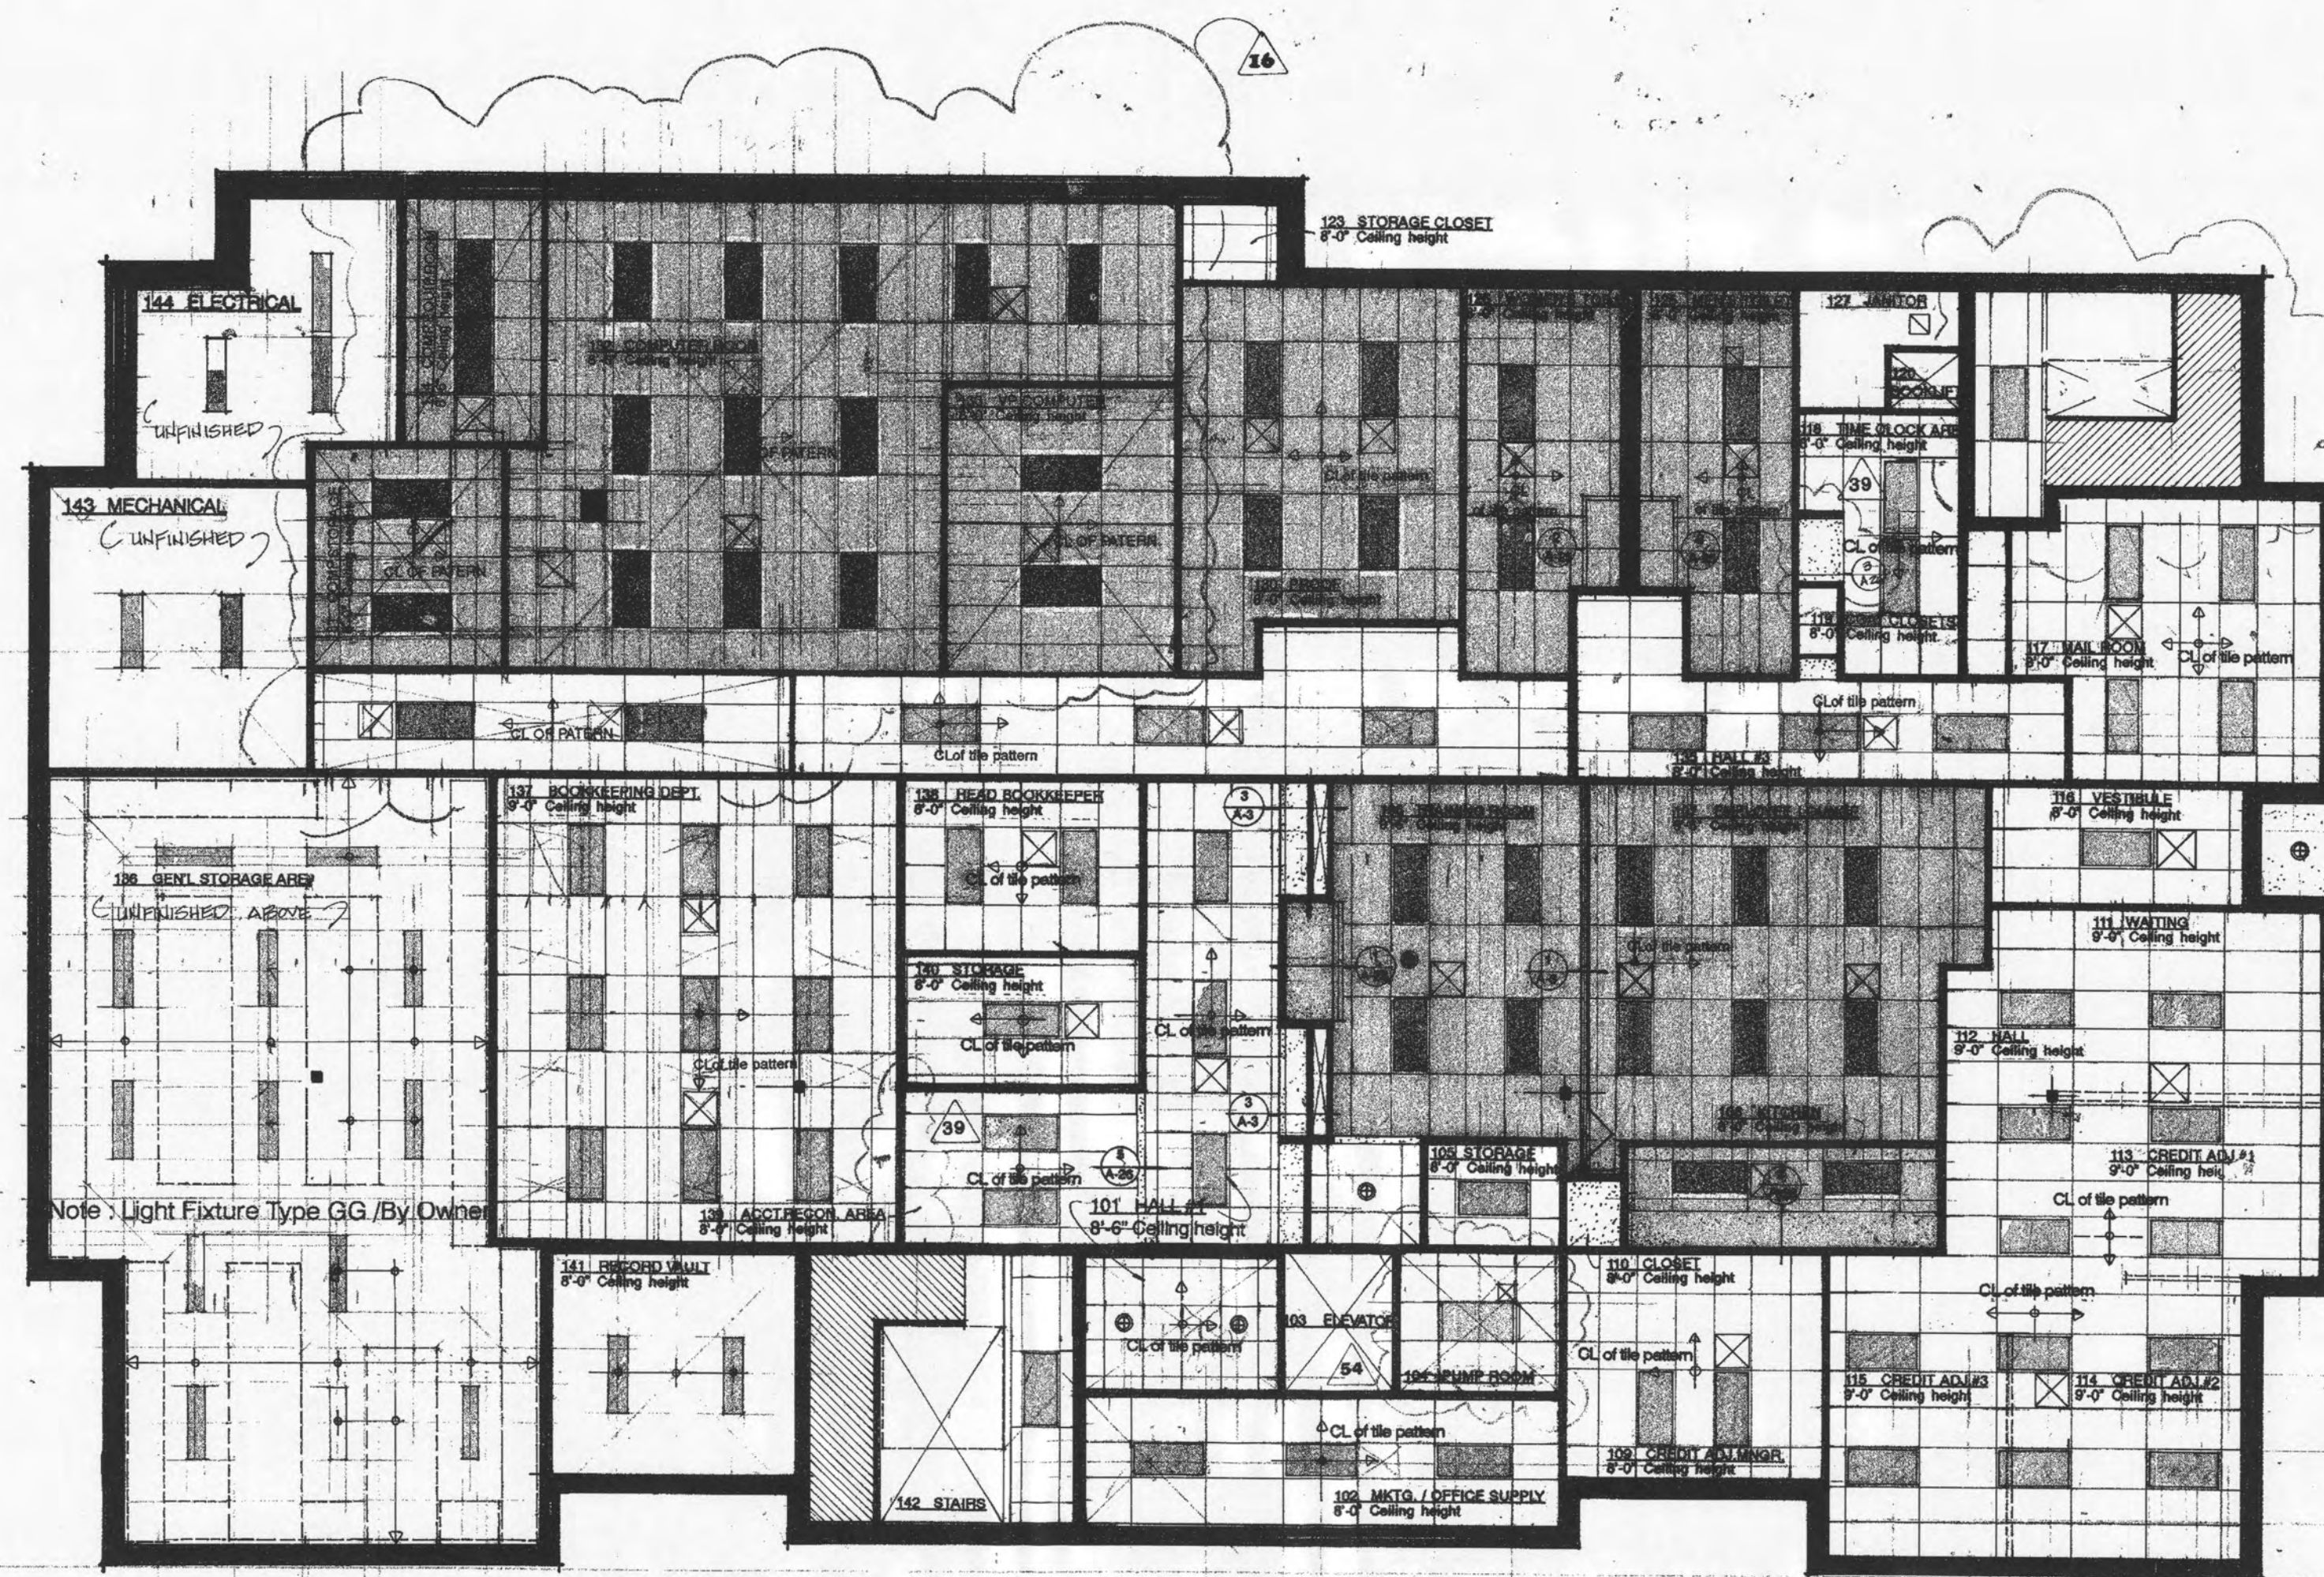

NOTE: SHADED AREAS TO HAVE 3 1/2" SOUND ATTENUATION BATT ABOVE CEILING TILES.


Reflected Ceiling Plan - Level I
SCALE: 1/8" = 1'-0"

job no	343	to		checked by	down by
issued	September 9/92	16 RV			
	March 2, 1993	39 RV			
	APRIL 16/93	54 RV			

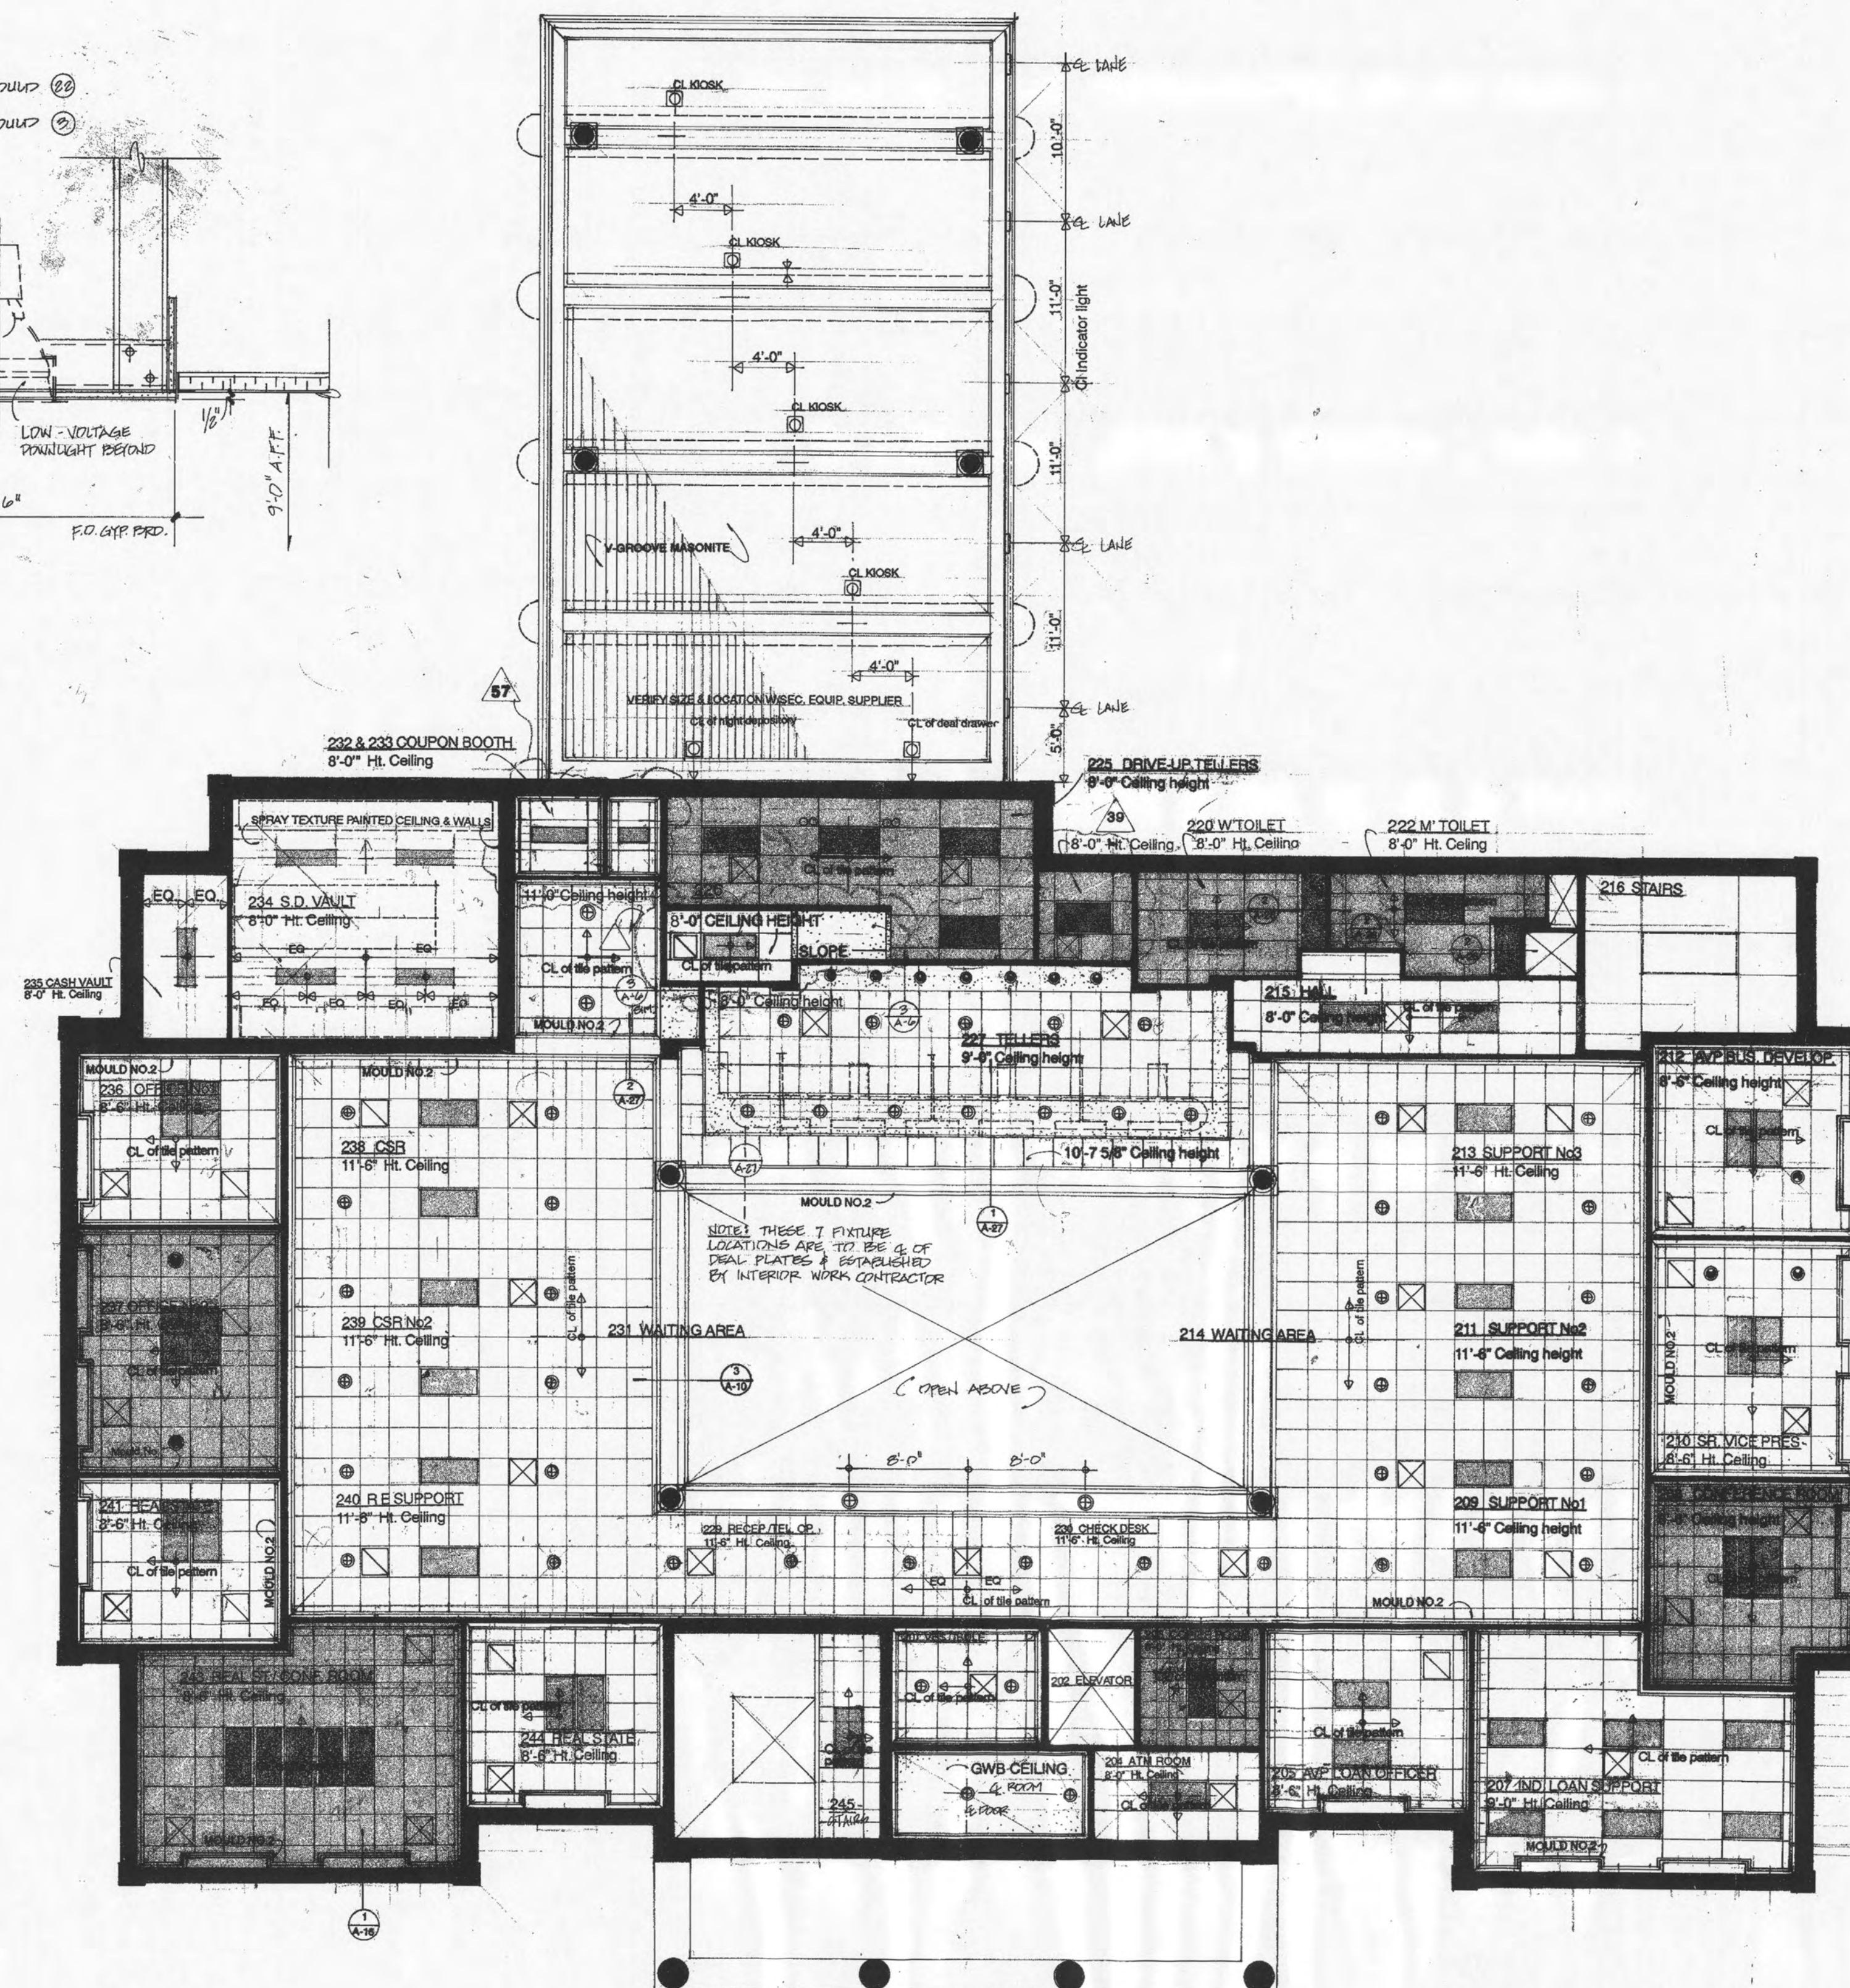
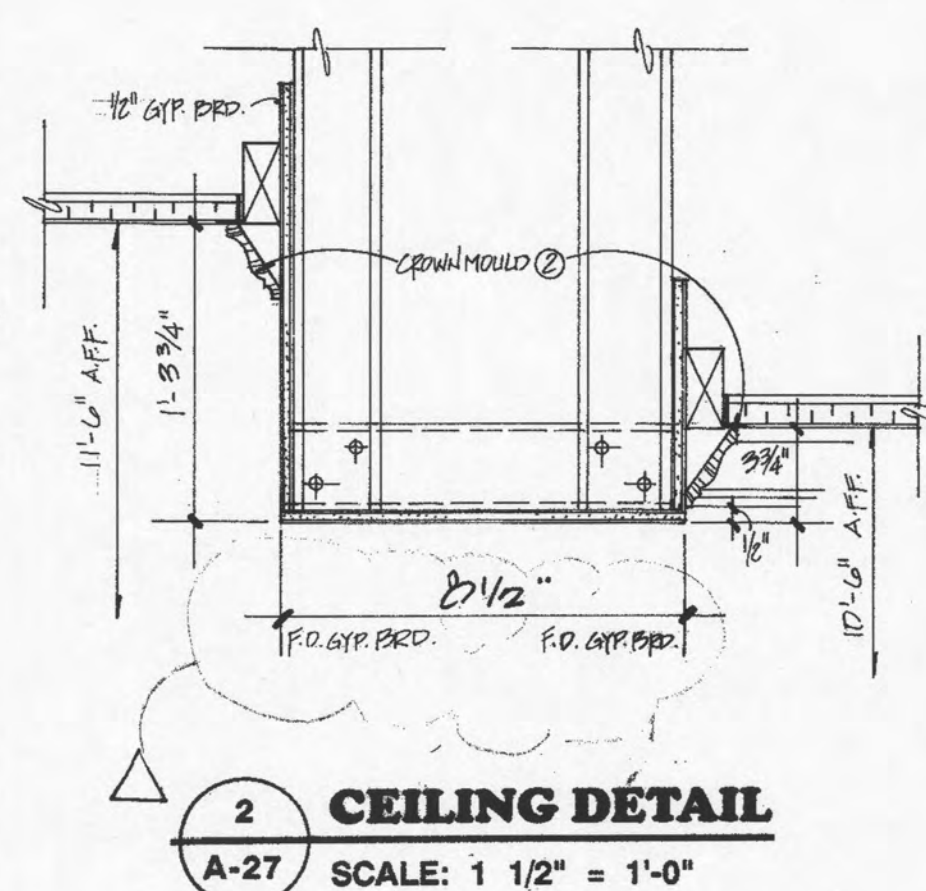












Reflected Ceiling Plan - Level II
SCALE :1/8" = 1'-0"

SP 1A16
D.P.E

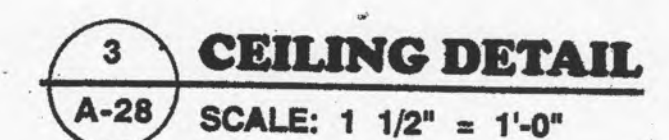

SCALE: 1/8" = 1'-0"

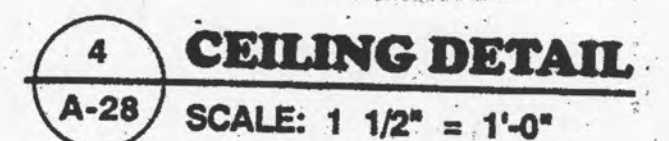 

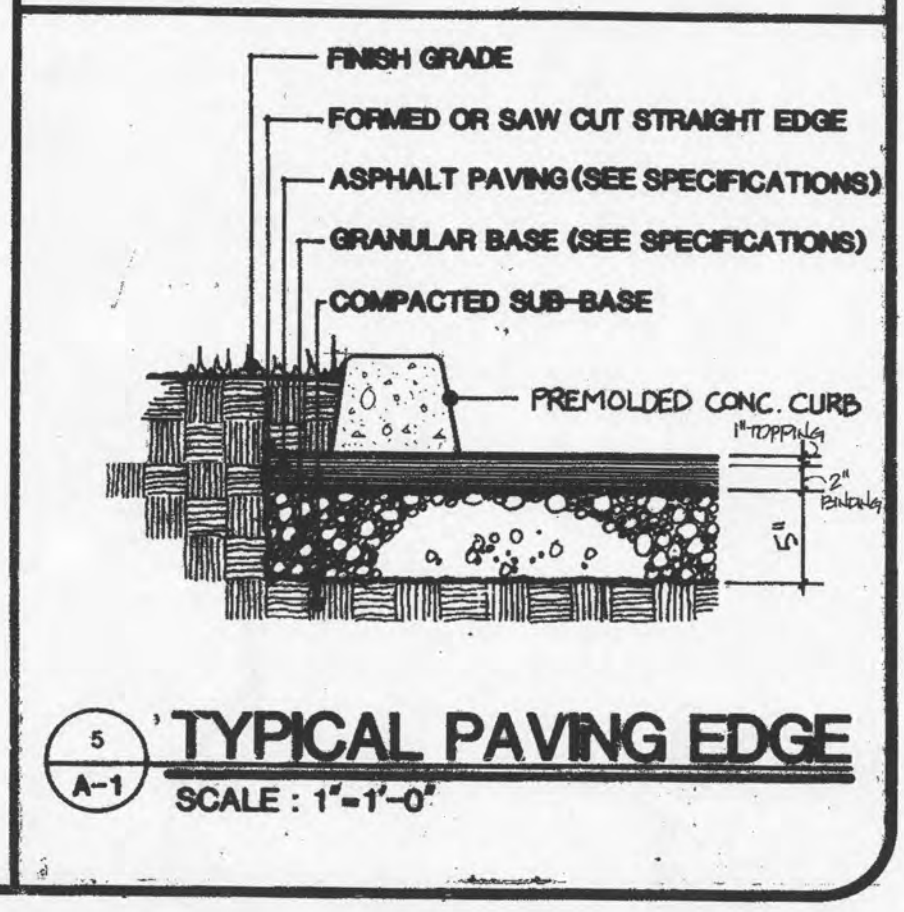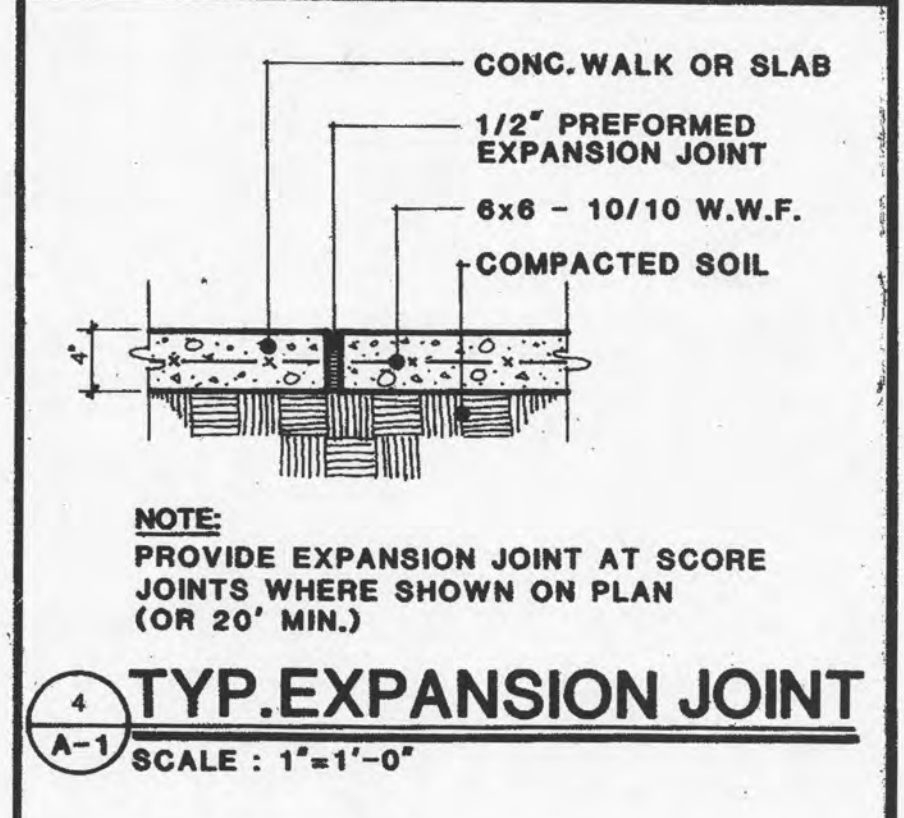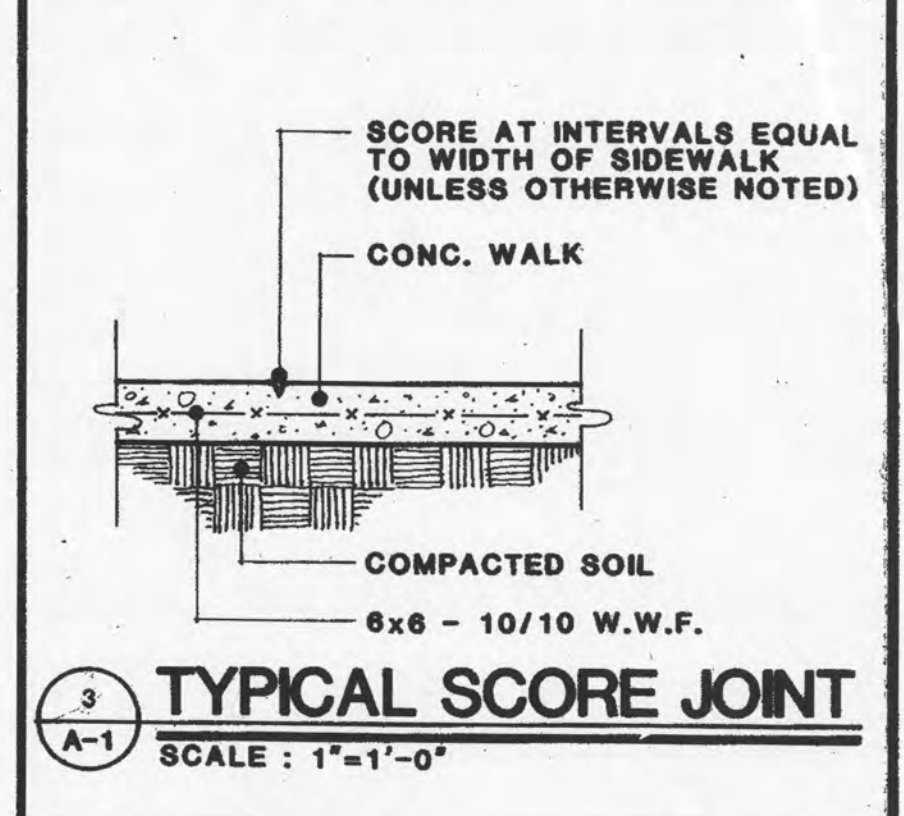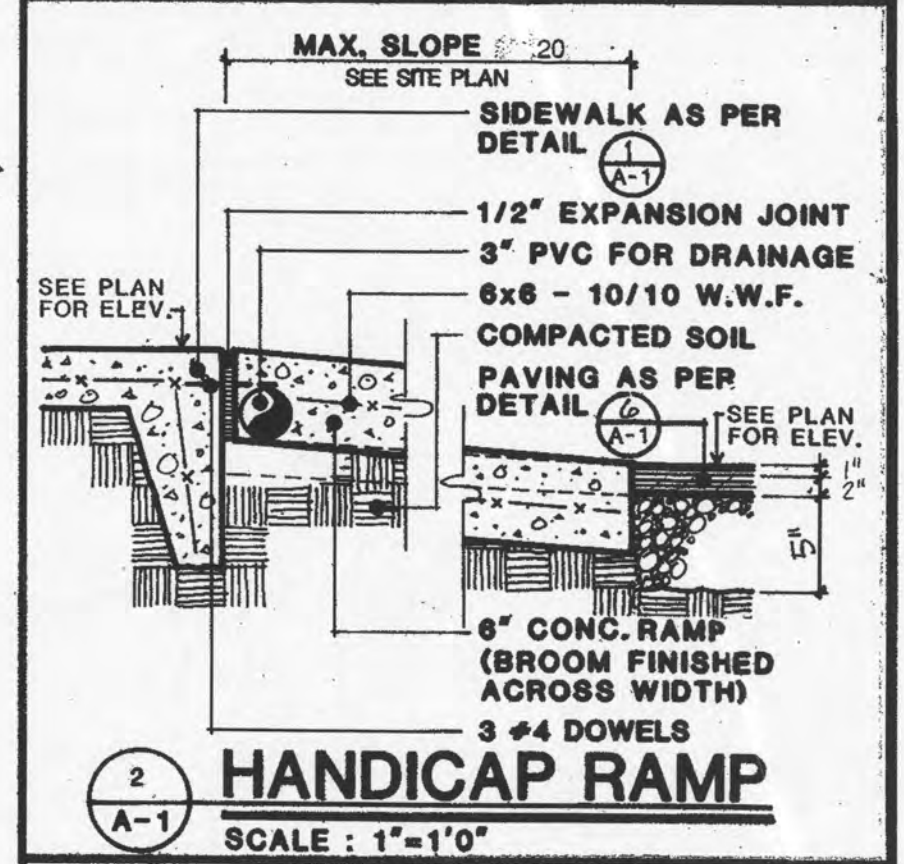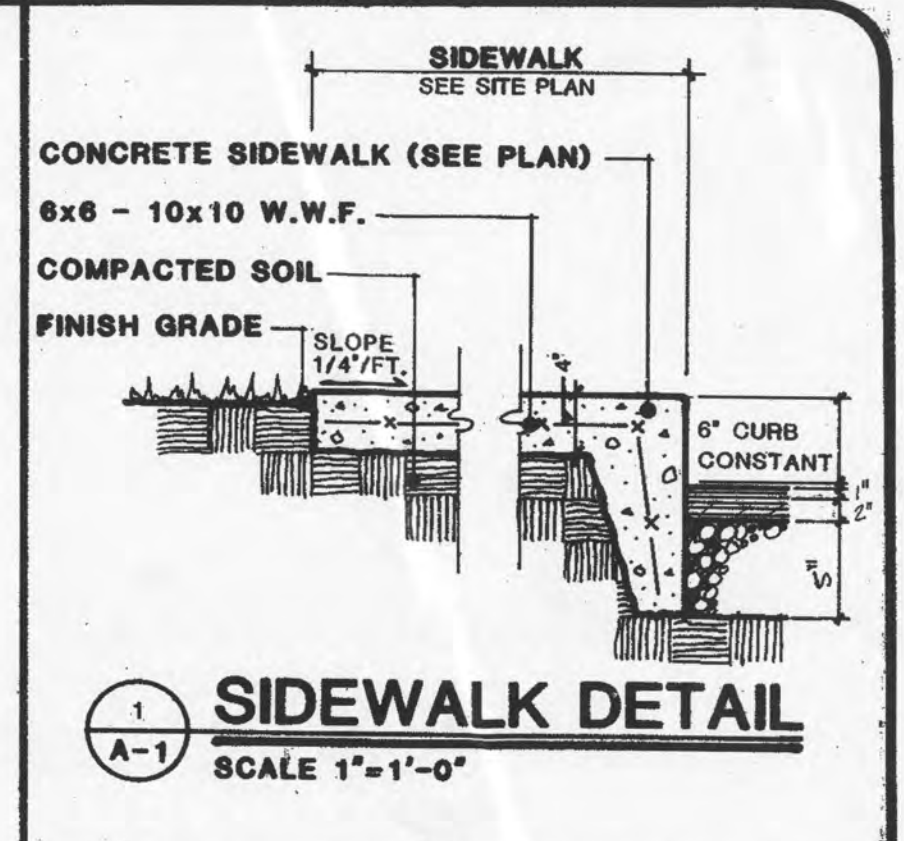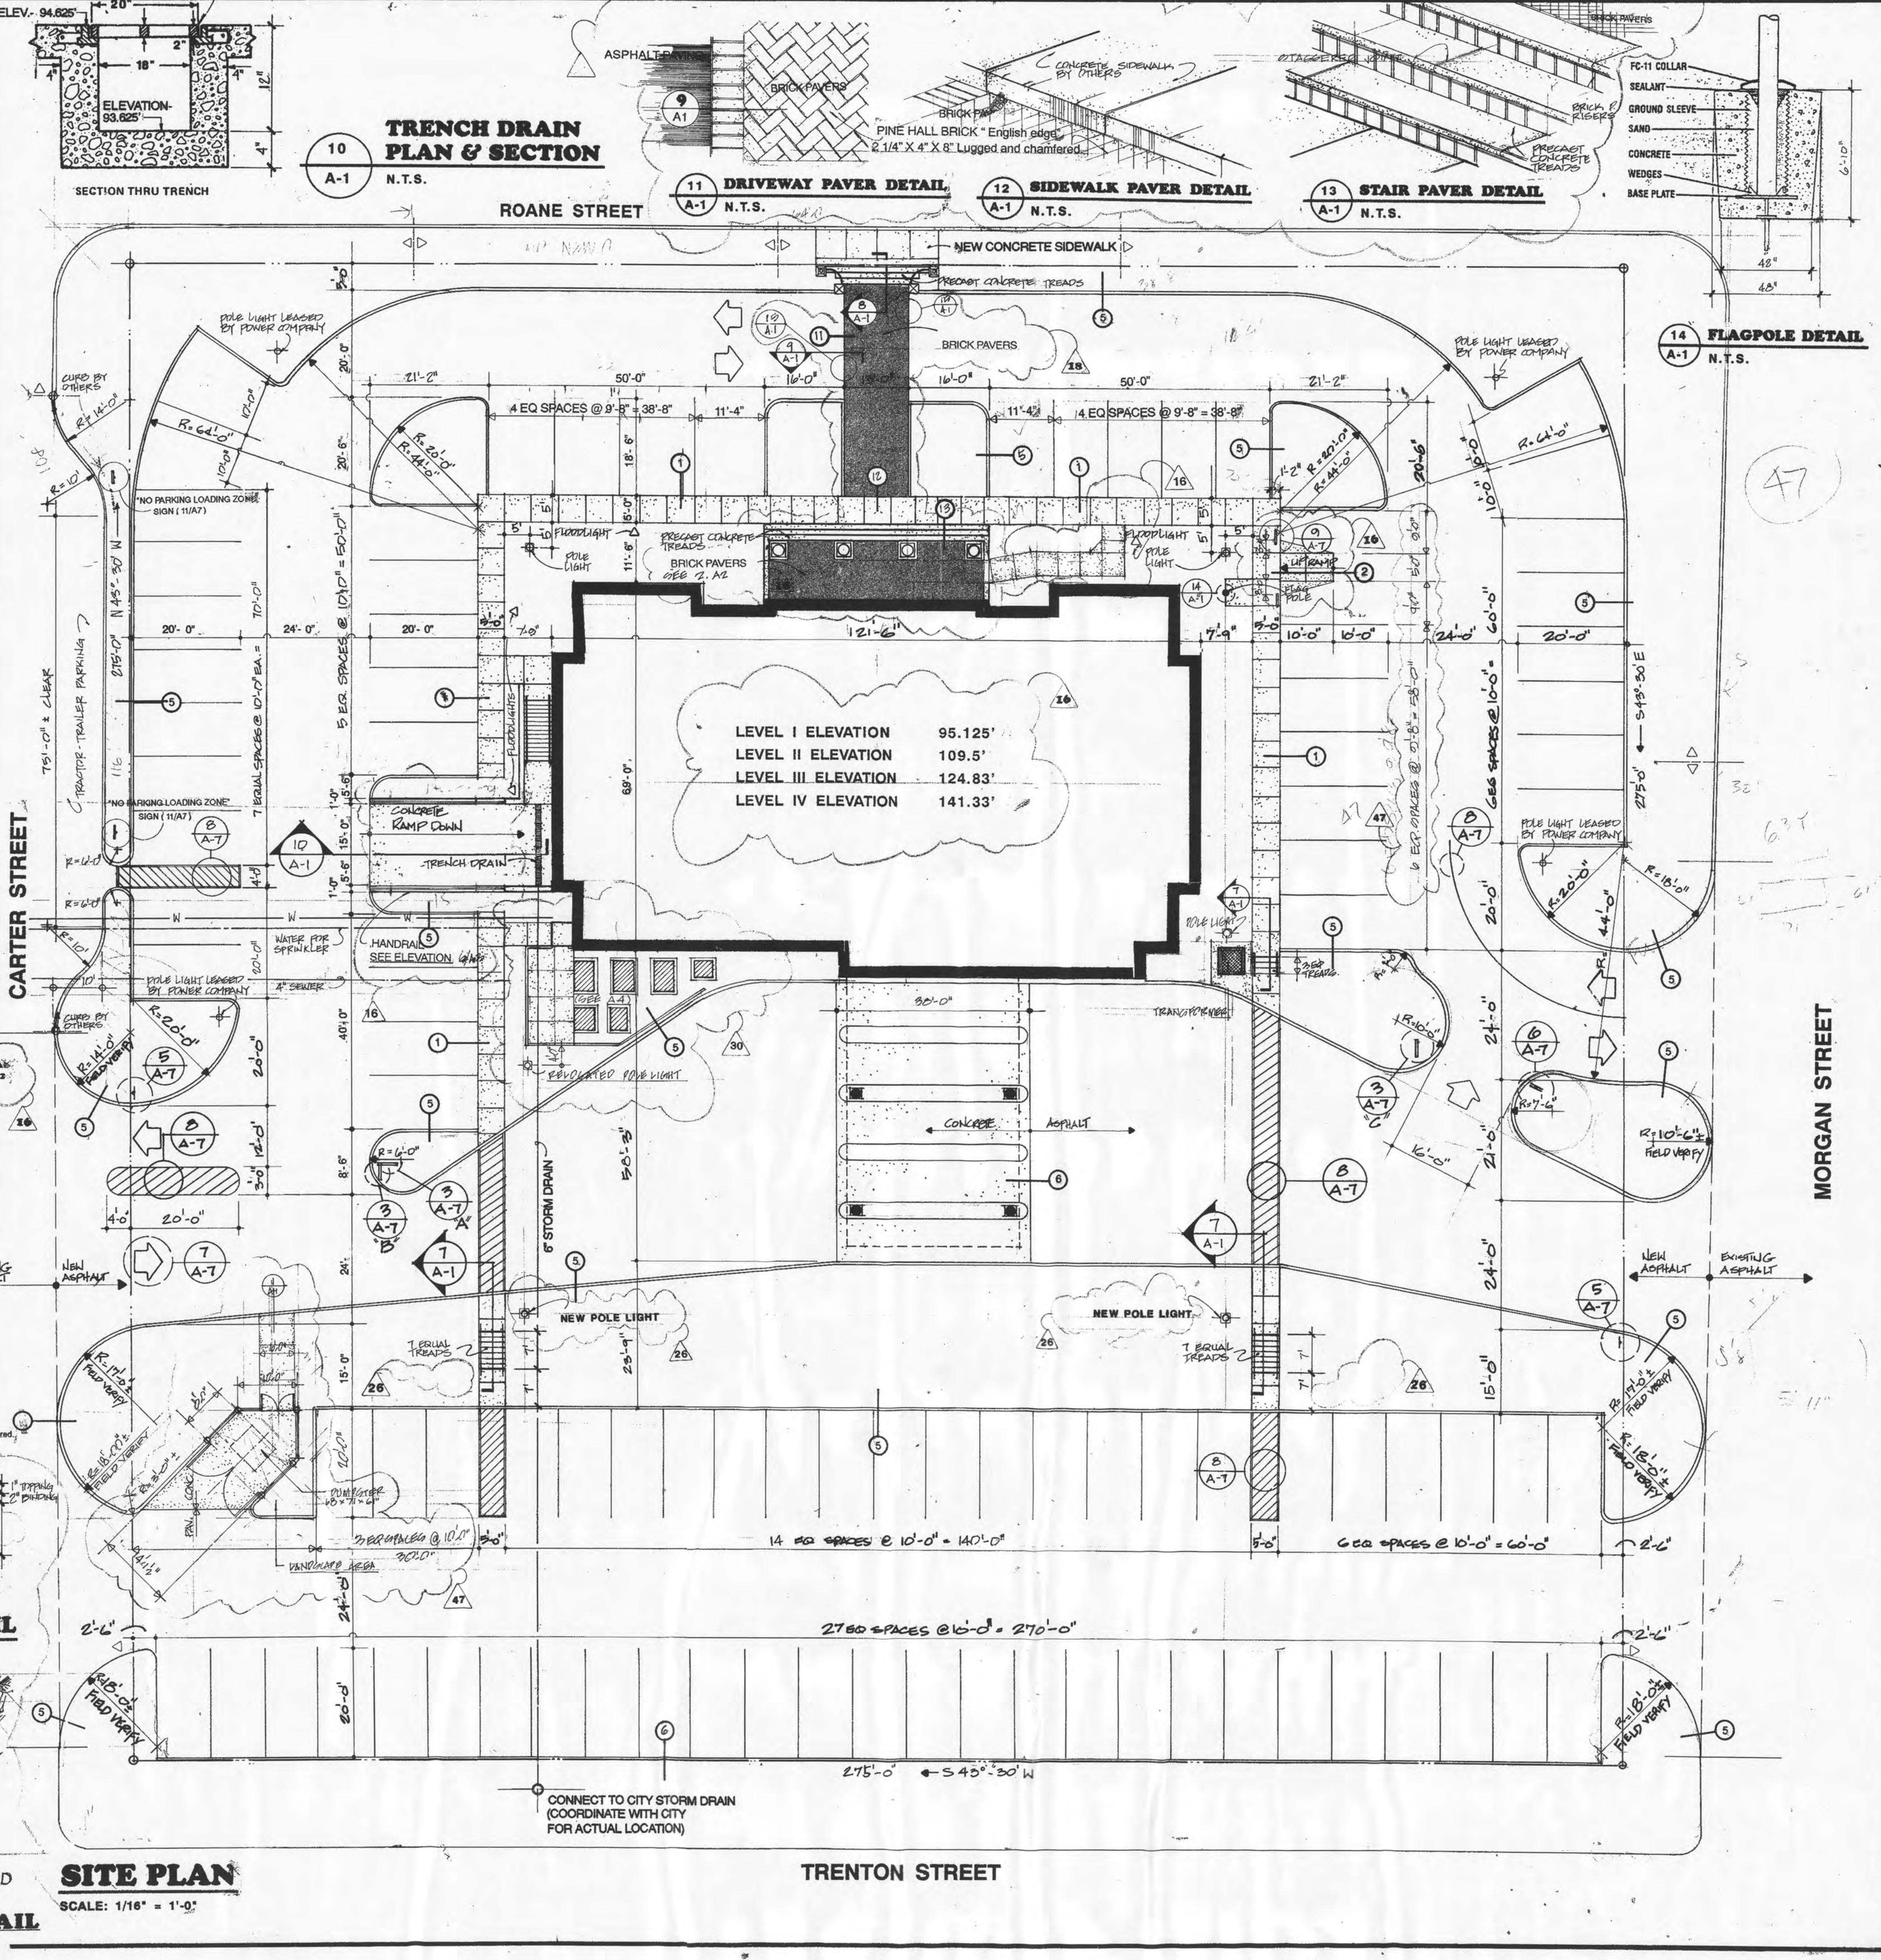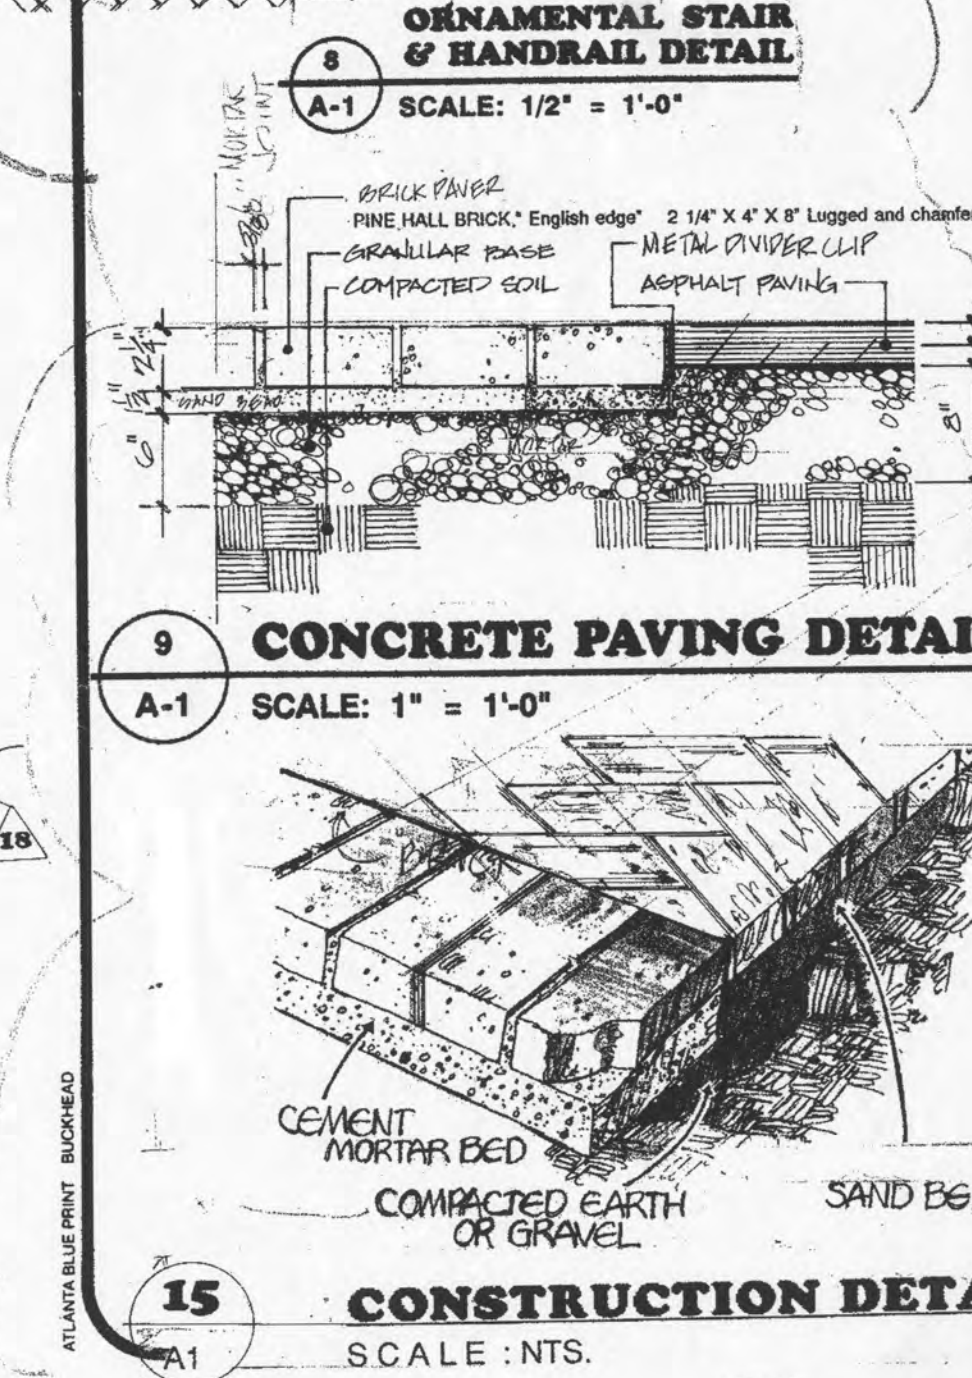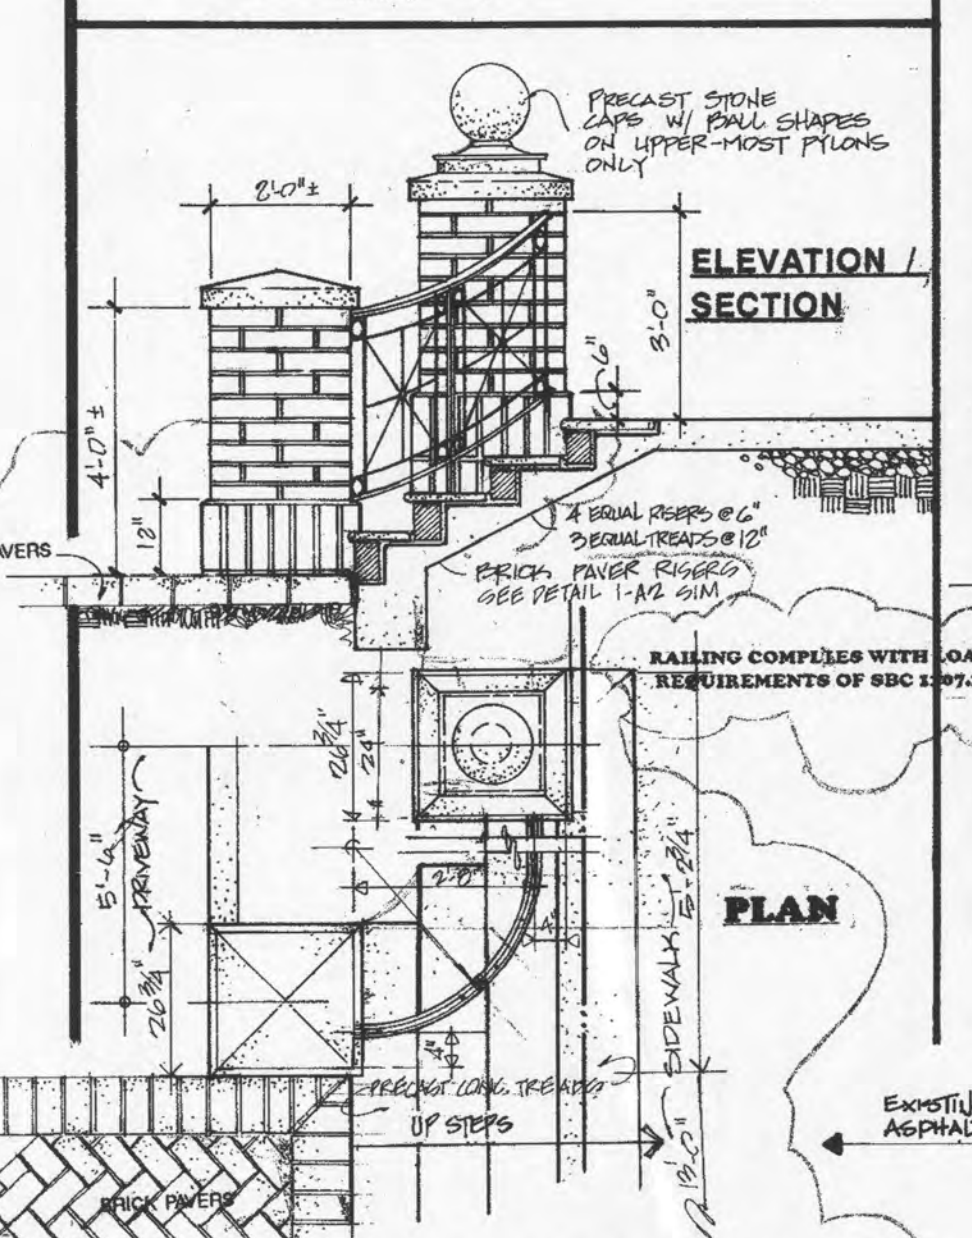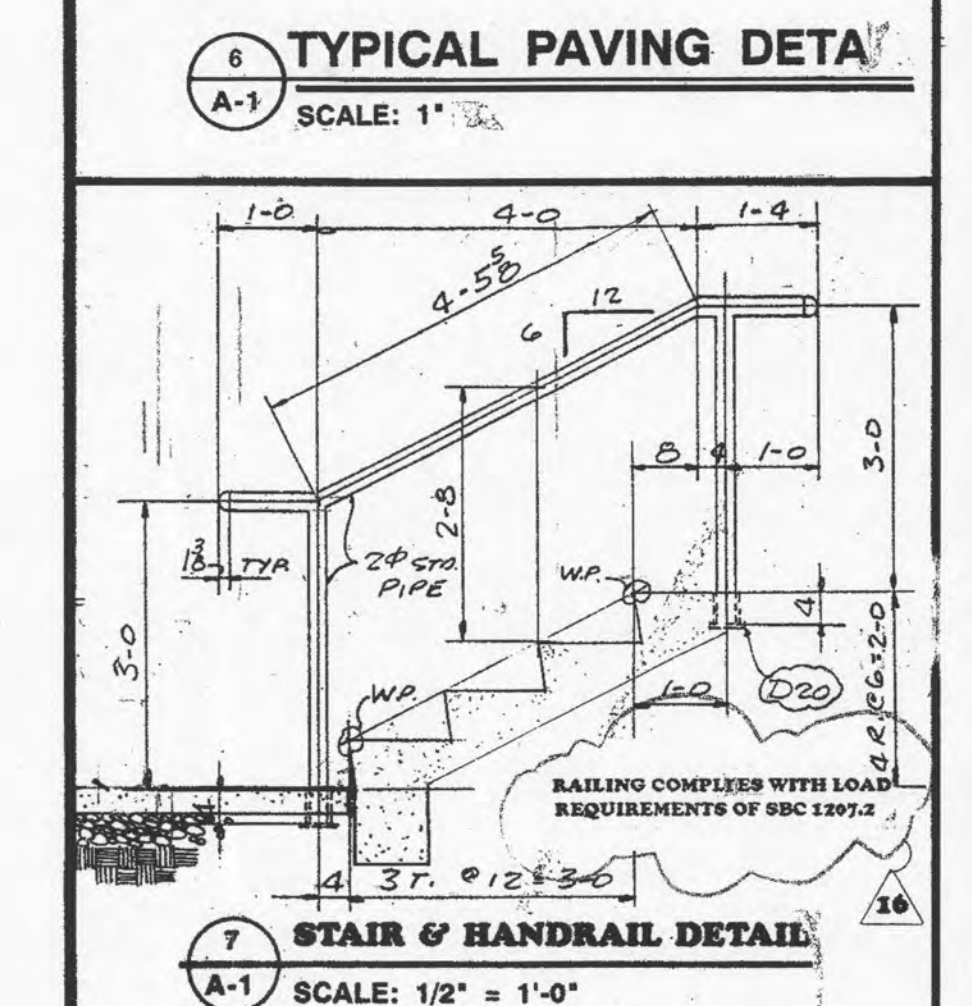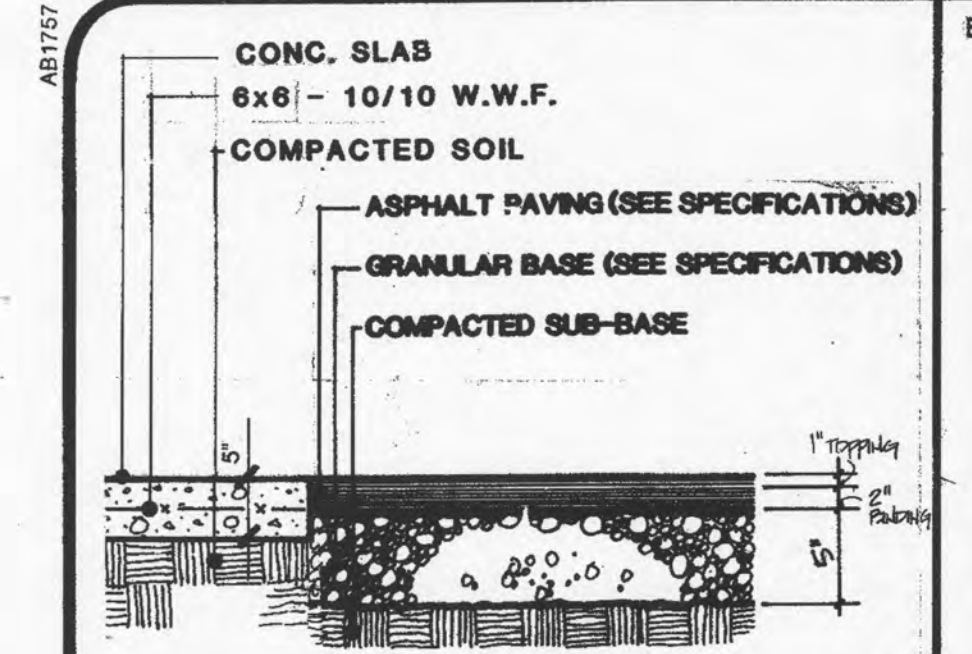

DATE: 3.4.92

DESIGNED BY: [Signature]

CHECKED BY: [Signature]

APPROVED BY: [Signature]

CONSULTANTS: [List of firms]

DESIGNERS: [List of firms]

CONSTRUCTION MANAGERS: [List of firms]

Concepts

ARCHITECTURAL FIRM

RELEASED FOR CONSTRUCTION

THIS DRAWING AND THE DESIGN THEREON ARE THE SOLE PROPERTY OF CONCEPTS ARCHITECTURAL FIRM. NO REPRODUCTION OR USE OF THESE DRAWINGS OR DESIGN FOR ANY PURPOSE OTHER THAN THAT SPECIFICALLY AUTHORIZED BY WRITING IS PROHIBITED.

SMITH COUNTY, MISSISSIPPI

STATE OF MISSISSIPPI

SITE PLAN AND DETAILS

 
 
 
A NEW MAIN OFFICE FACILITY FOR:

Bank of Roane County

HARRIMAN, TENNESSEE




A-1


28 SHEETS



5
A-29

    DETAIL
SCALE: NTS








NOTES:


1. C.J. ON PLAN INDICATES CONTROL JOINT IN SLAB ON GRADE.
2. CONSTRUCTION JOINTS MAY BE PROVIDED IN LIEU OF CONTROL JOINTS.

* NOTE: PROVIDE (4) - 3/4" Ø A.B.'S

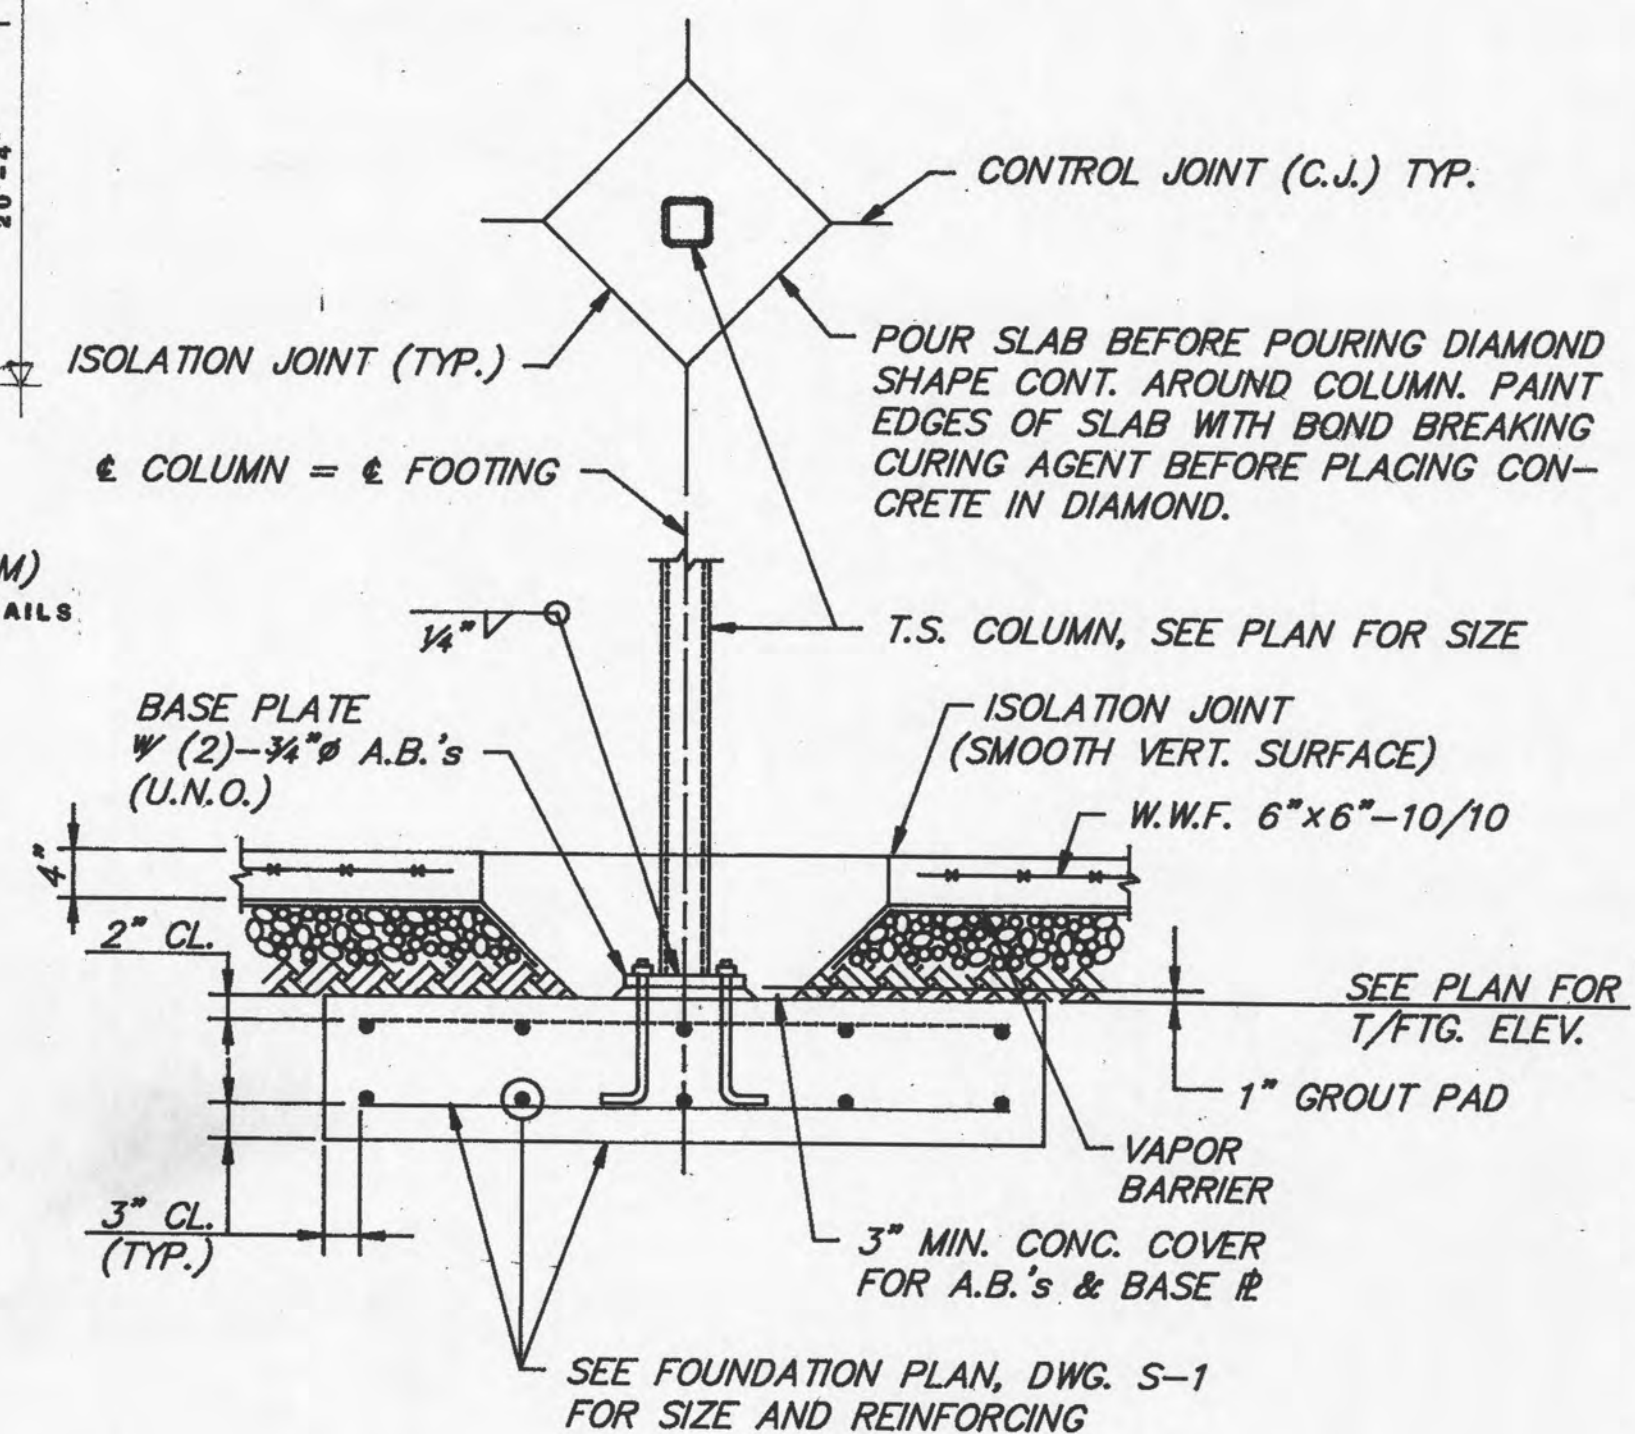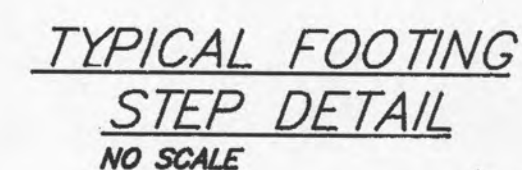


SECTION
 $\frac{3}{4}'' = 1'-0''$





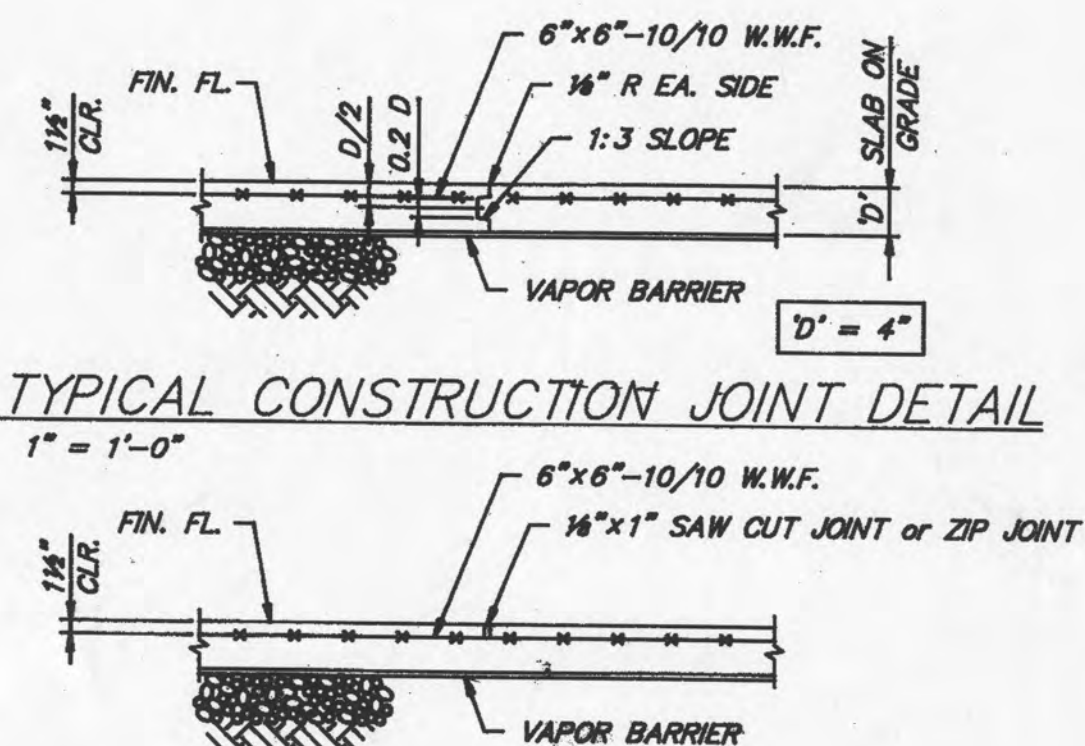


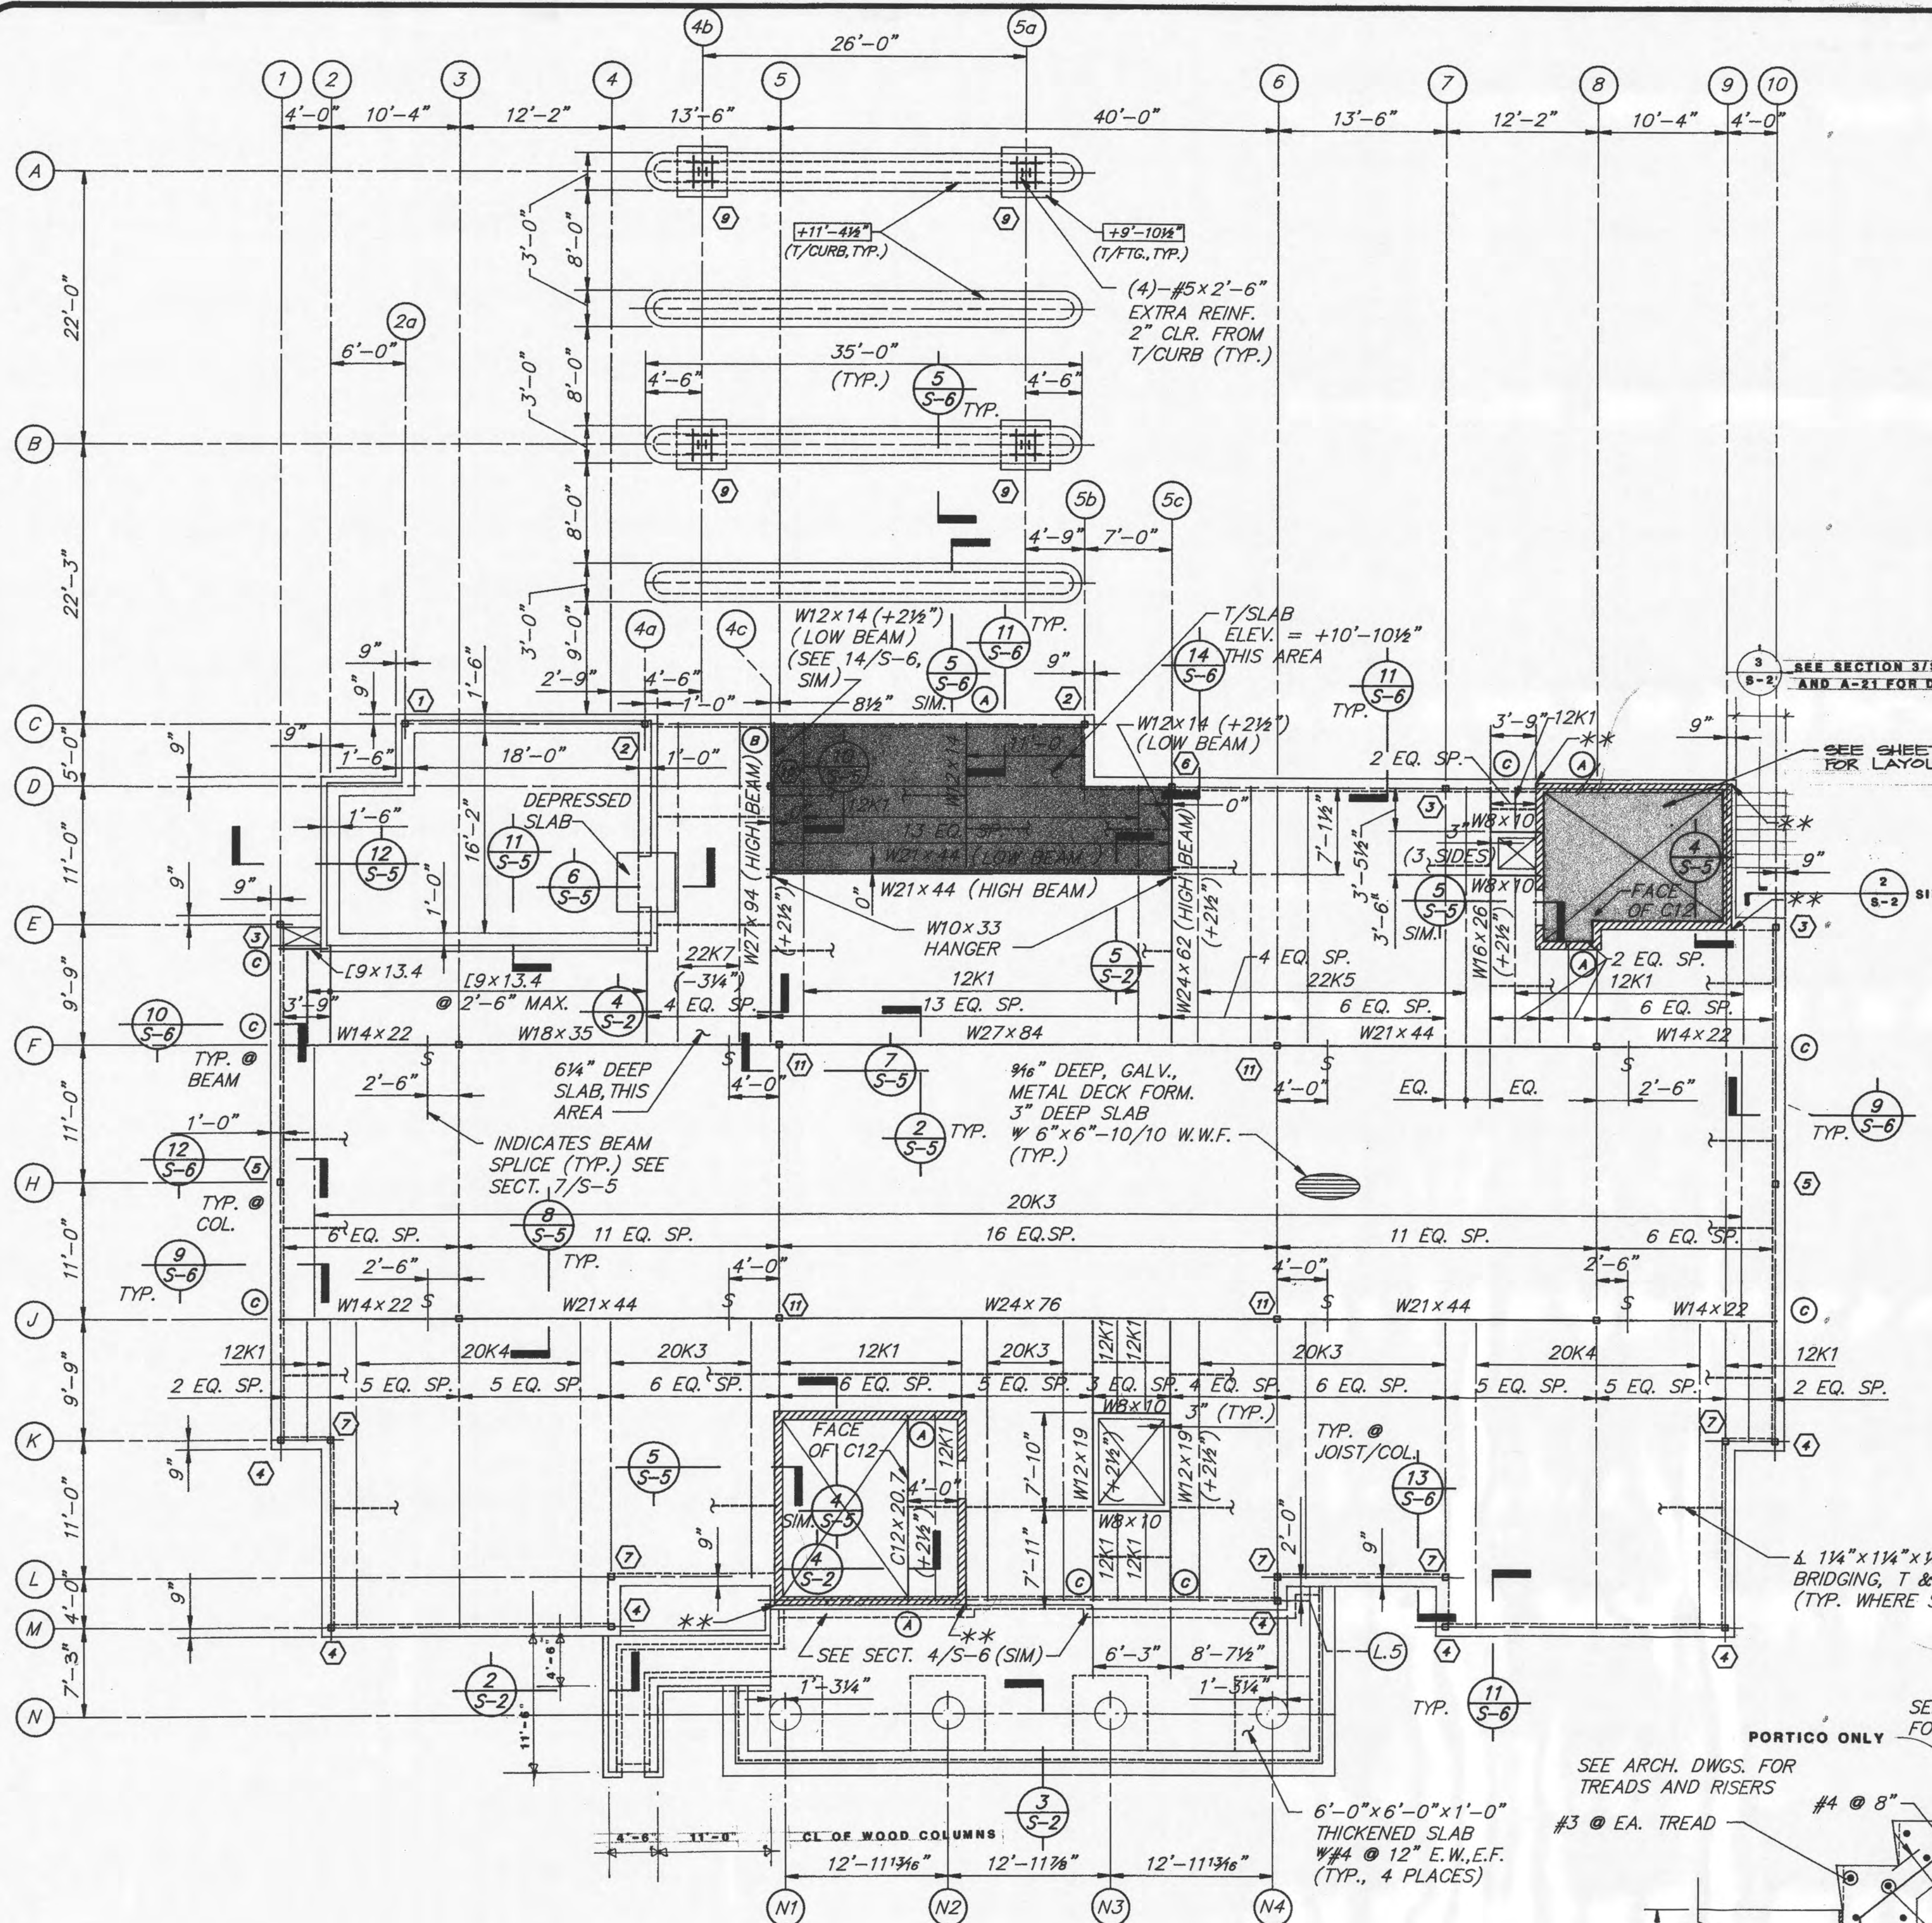

MARK	COLUMN SIZE	BASE #
1	T.S. 4x4x1/4"	SEE DETAIL A, THIS DWG.
2	T.S. 4x4x1/4"	3/4"x5"x1'-0"
3*	T.S. 4x4x1/4"	1 1/4"x5"x1'-0"
4*	T.S. 4x4x1/4"	3/4"x5"x1'-0"
5*	T.S. 5x5x1/4"	1 1/4"x6"x1'-1"
6*	T.S. 5x5x1/4"	1 1/2"x6"x1'-1"
7*	T.S. 4x4x1/4"	SEE DETAIL A, THIS DWG.
8	W.C. x 25	SEE SECT. 5/S-6
10*	T.S. 5x5x1/4"	SEE SECT. 10/S-5
11	T.S. 6x6x1/2"	SEE SECT. 2/S-5

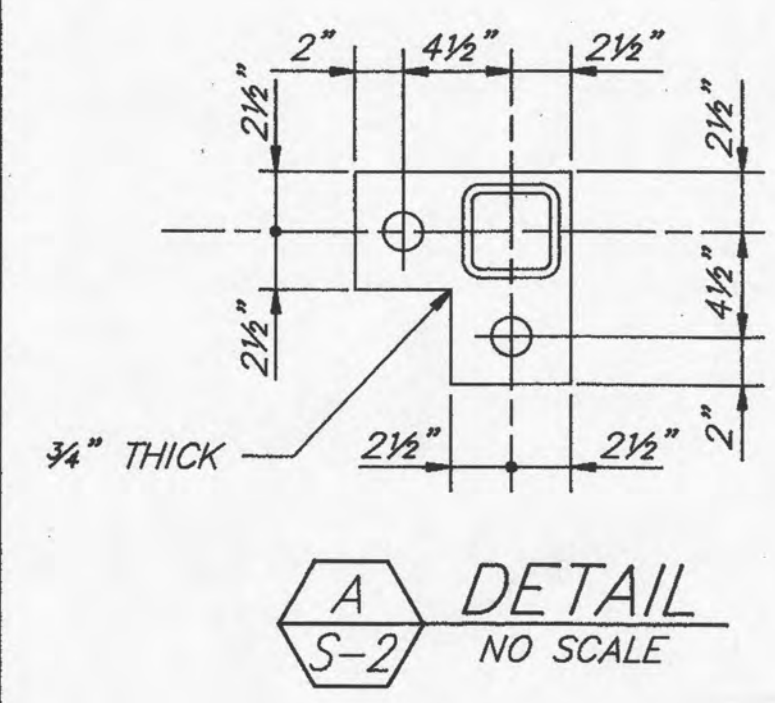

- NOTES:
1. COLUMNS DENOTED ON LEVEL II FLOOR PLAN ARE AT LEVEL II, SUPPORTING LEVEL III FLOOR.
 2. ALL BASE #S HAVE (2)-3/4" A307 A.B., U.N.O.
 3. * DENOTES TWO STORY COLUMN TO ROOF FRAMING

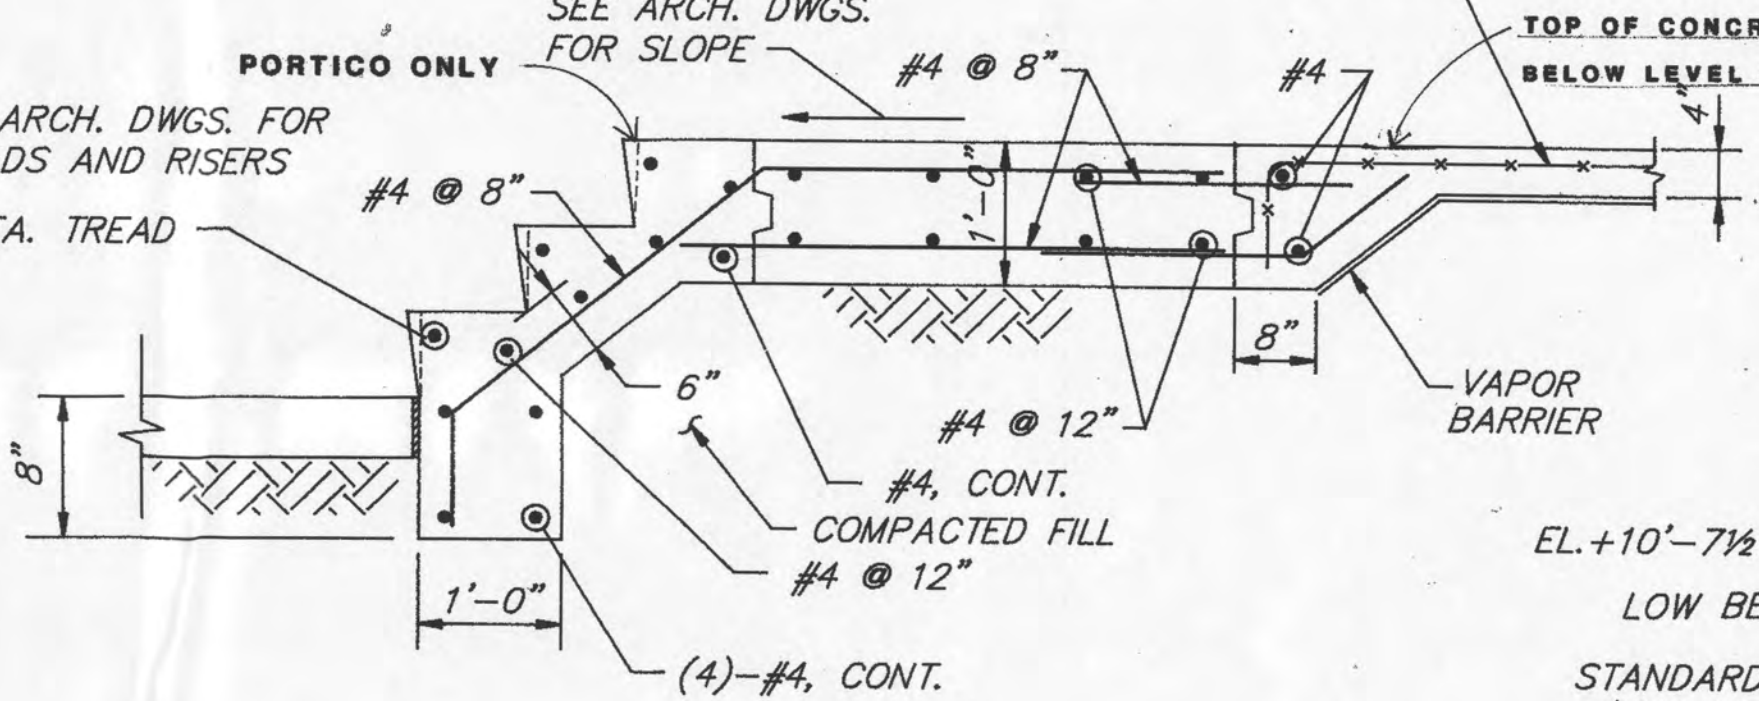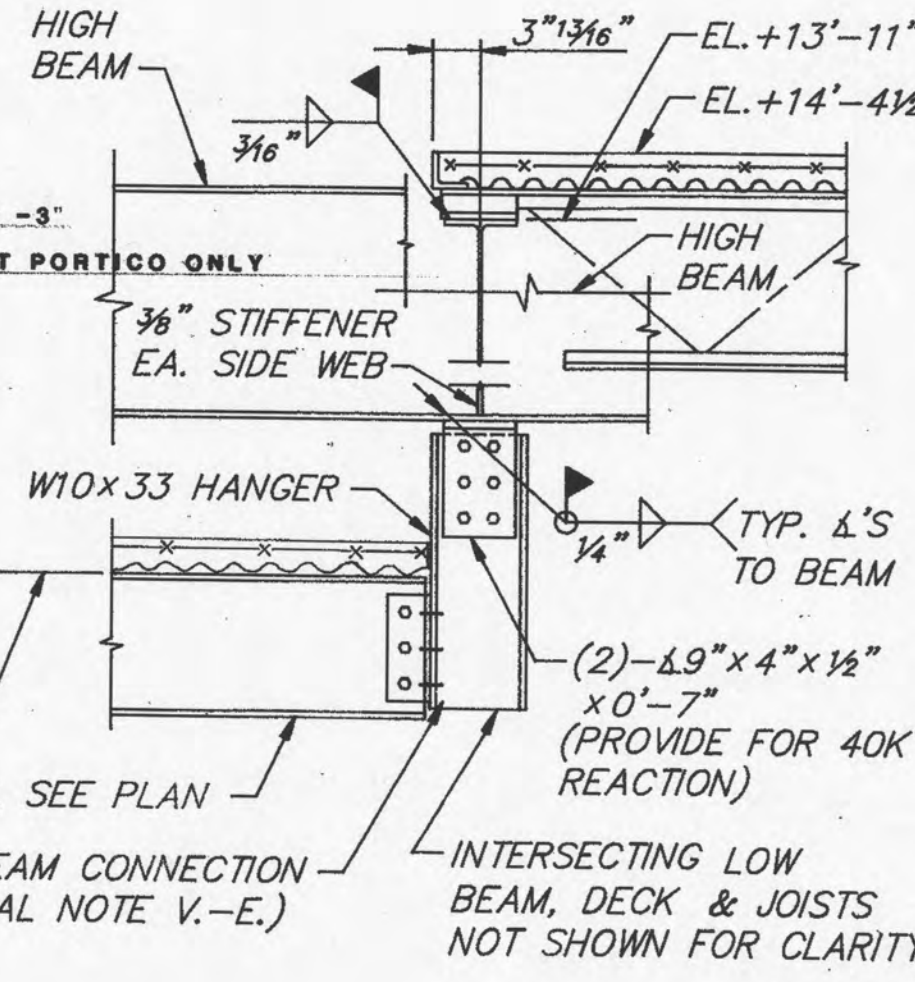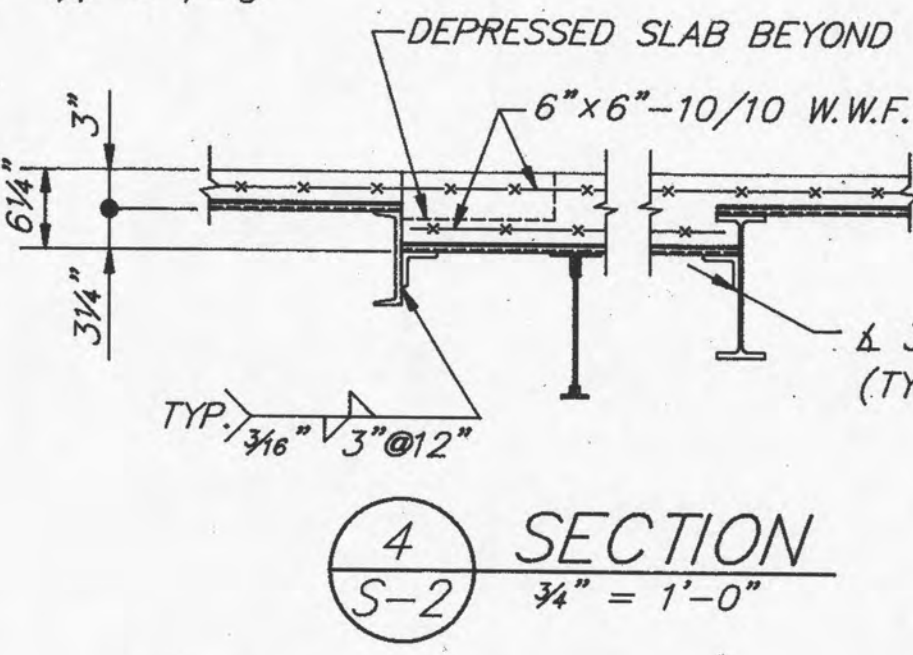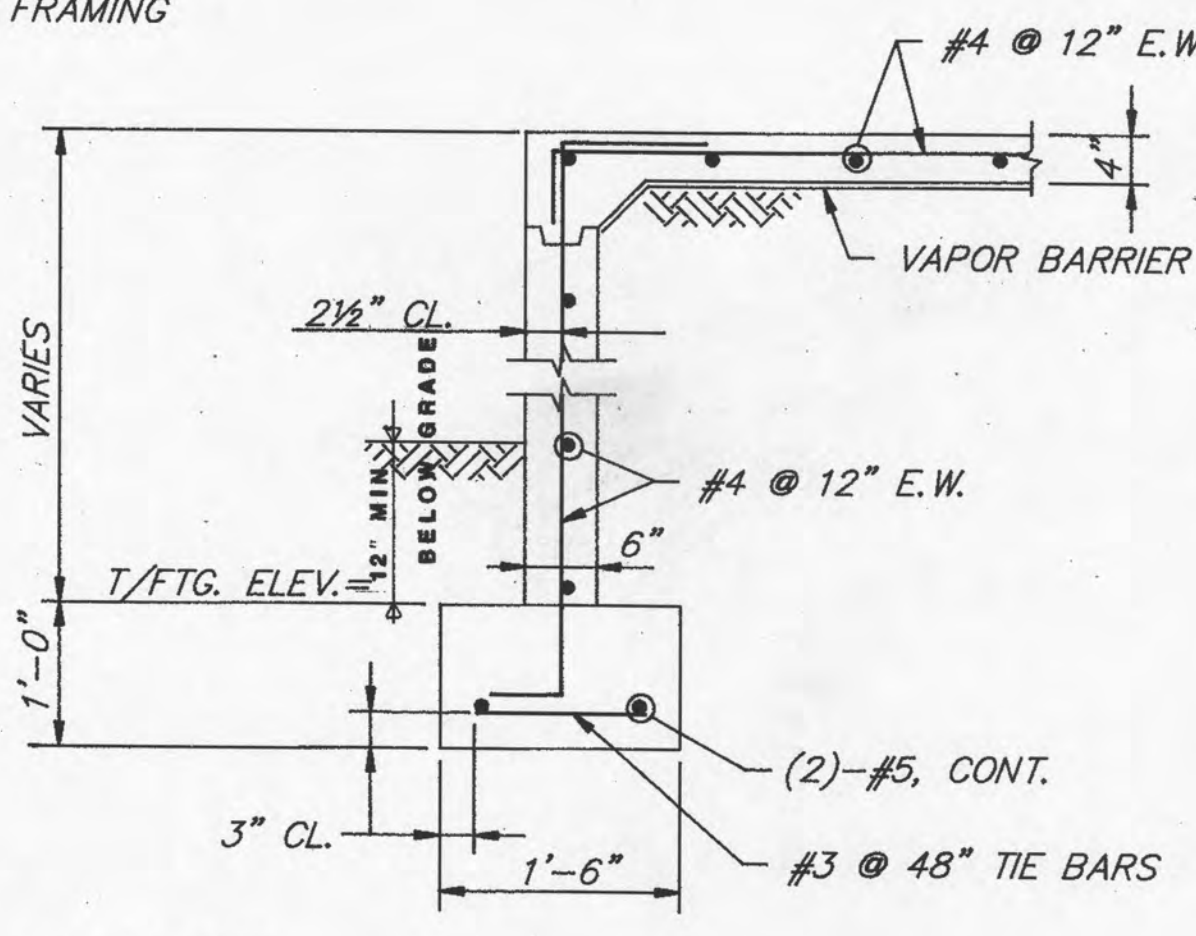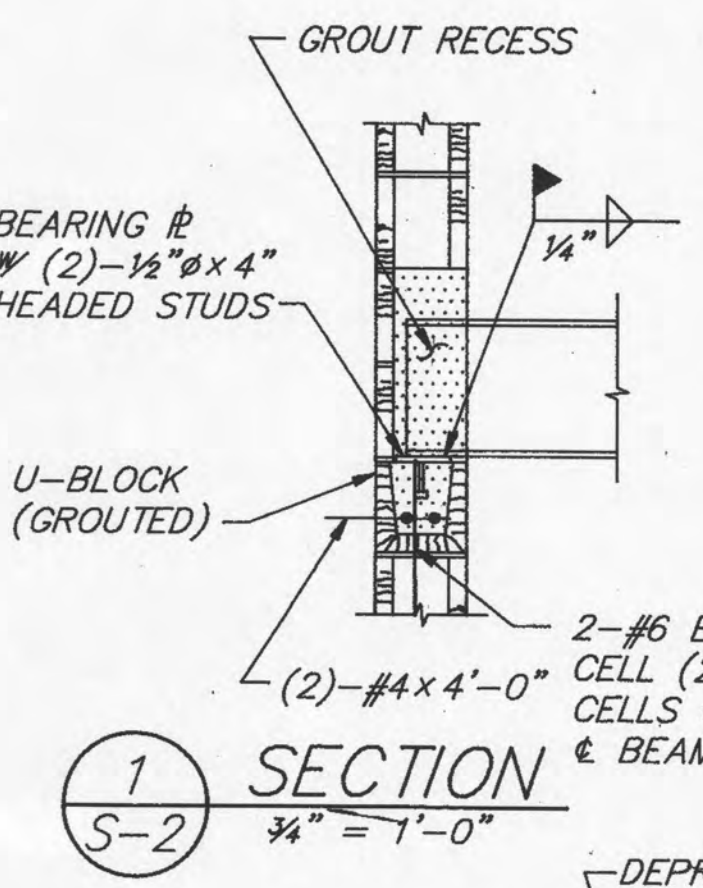

FLOOR FRAMING PLAN - LEVEL II

1/8" = 1'-0"

T/LEVEL II SLAB ELEV. = +14'-4 1/2", U.N.O.

--- INDICATES T/FTG. ELEV.

** PROVIDE (4)-#6 IN TWO END CELLS OF WALL. LAP 40# AS REQ'D & DOWEL INTO FTG. BELOW.

MARK	SIZE	COMMENTS
A	1/2"x6"x0'-8"	SEE 1/S-2
B	1 1/2"x6"x1'-0"	SEE 10/S-6
C	3/4"x6"x0'-8"	SEE 10/S-6

343

DATE

DESIGN

CHECKED

APPROVED

CONSULTANTS

DESIGNERS

CONSTRUCTION MANAGERS

CONCEPTS

ARCHITECTURAL

ENGINEERING

DESIGN

INC.

RELEASED FOR CONSTRUCTION

THIS DRAWING AND THE DESIGN THEREON ARE THE SOLE PROPERTY OF CONCEPTS ARCHITECTURAL ENGINEERING DESIGN, INC. NO PART OF THIS DRAWING OR DESIGN MAY BE REPRODUCED OR USED IN ANY MANNER WITHOUT THE WRITTEN PERMISSION OF CONCEPTS ARCHITECTURAL ENGINEERING DESIGN, INC.

FOR CONSTRUCTION

CONCEPTS ARCHITECTURAL ENGINEERING DESIGN, INC.

1407 256 0360

1407 256 0360

DATE

JUNE 10, 1992

PROJECT

S-2

BY

J. JONES


FLOOR FRAMING PLAN - LEVEL II

A NEW MAIN OFFICE FACILITY FOR:


Bank of Roane County

HARRIMAN, TENNESSEE

343

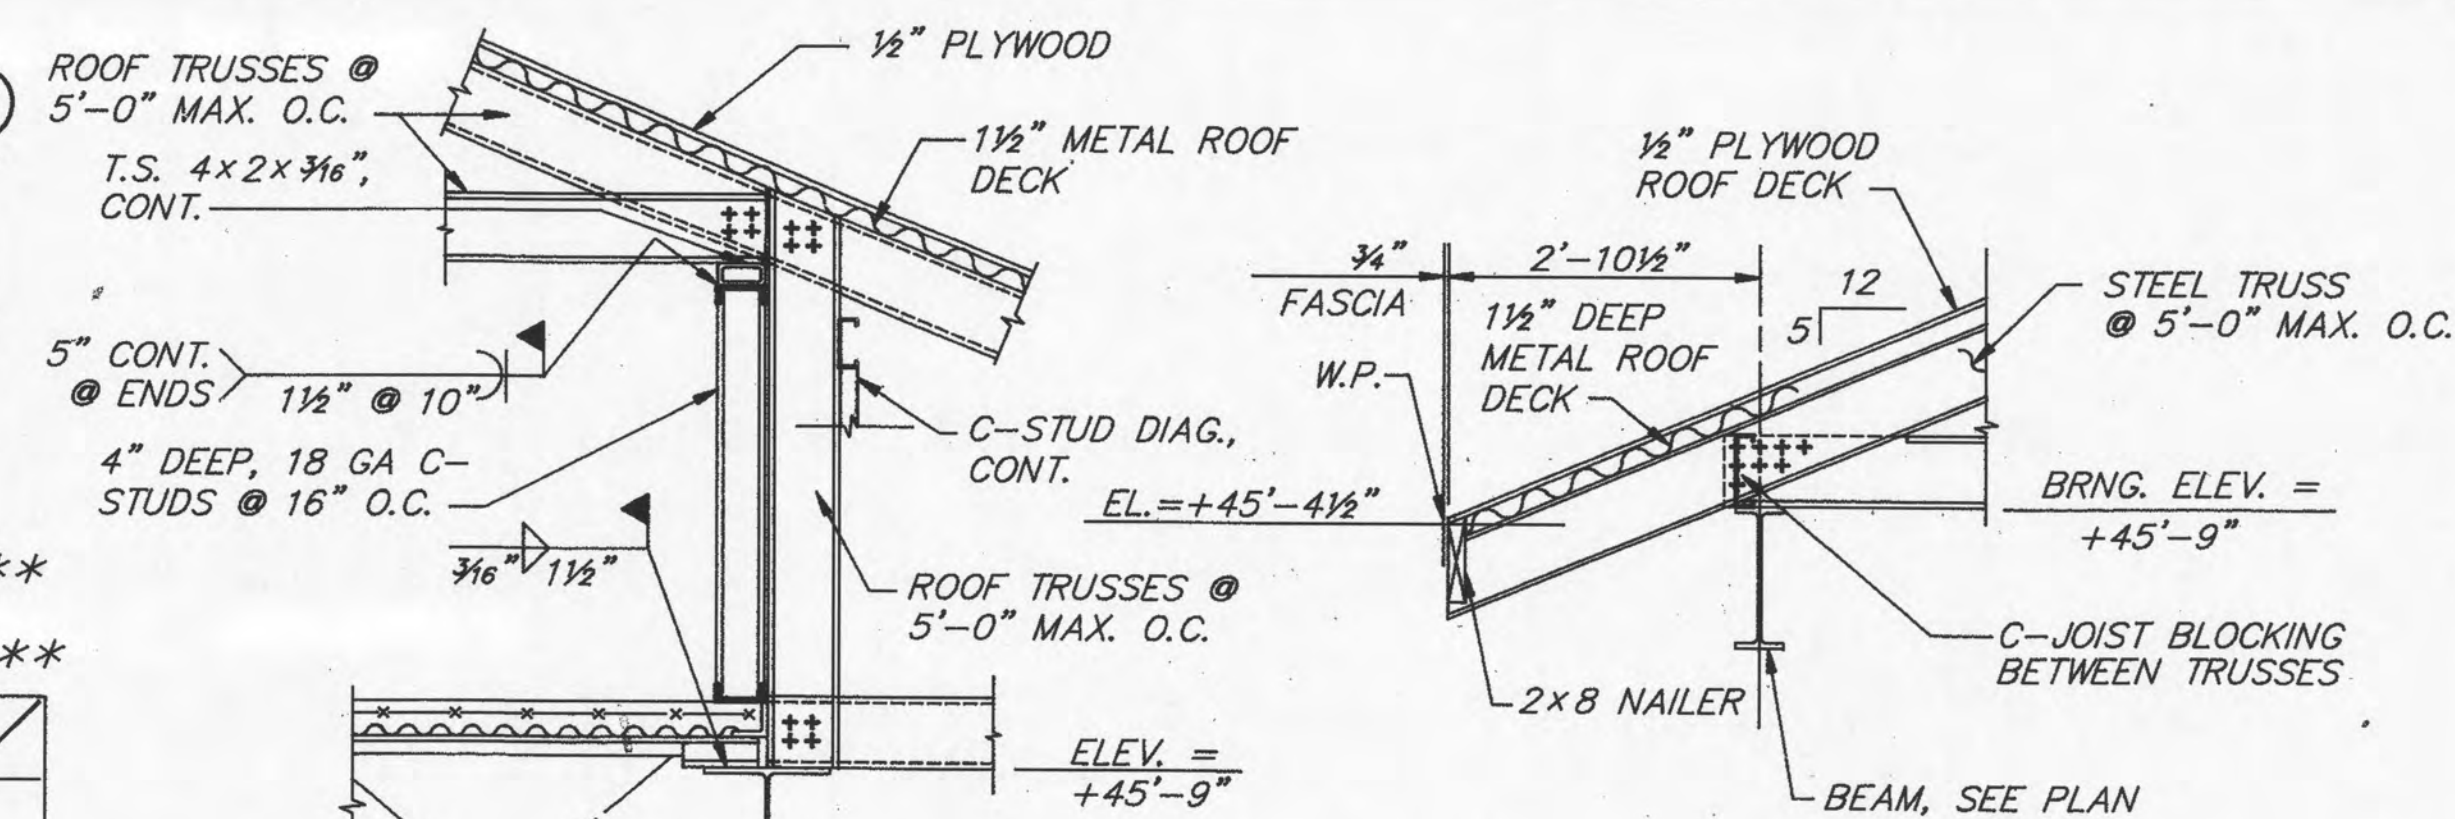

SECTION
 $\frac{3}{4}" = 1'-0"$

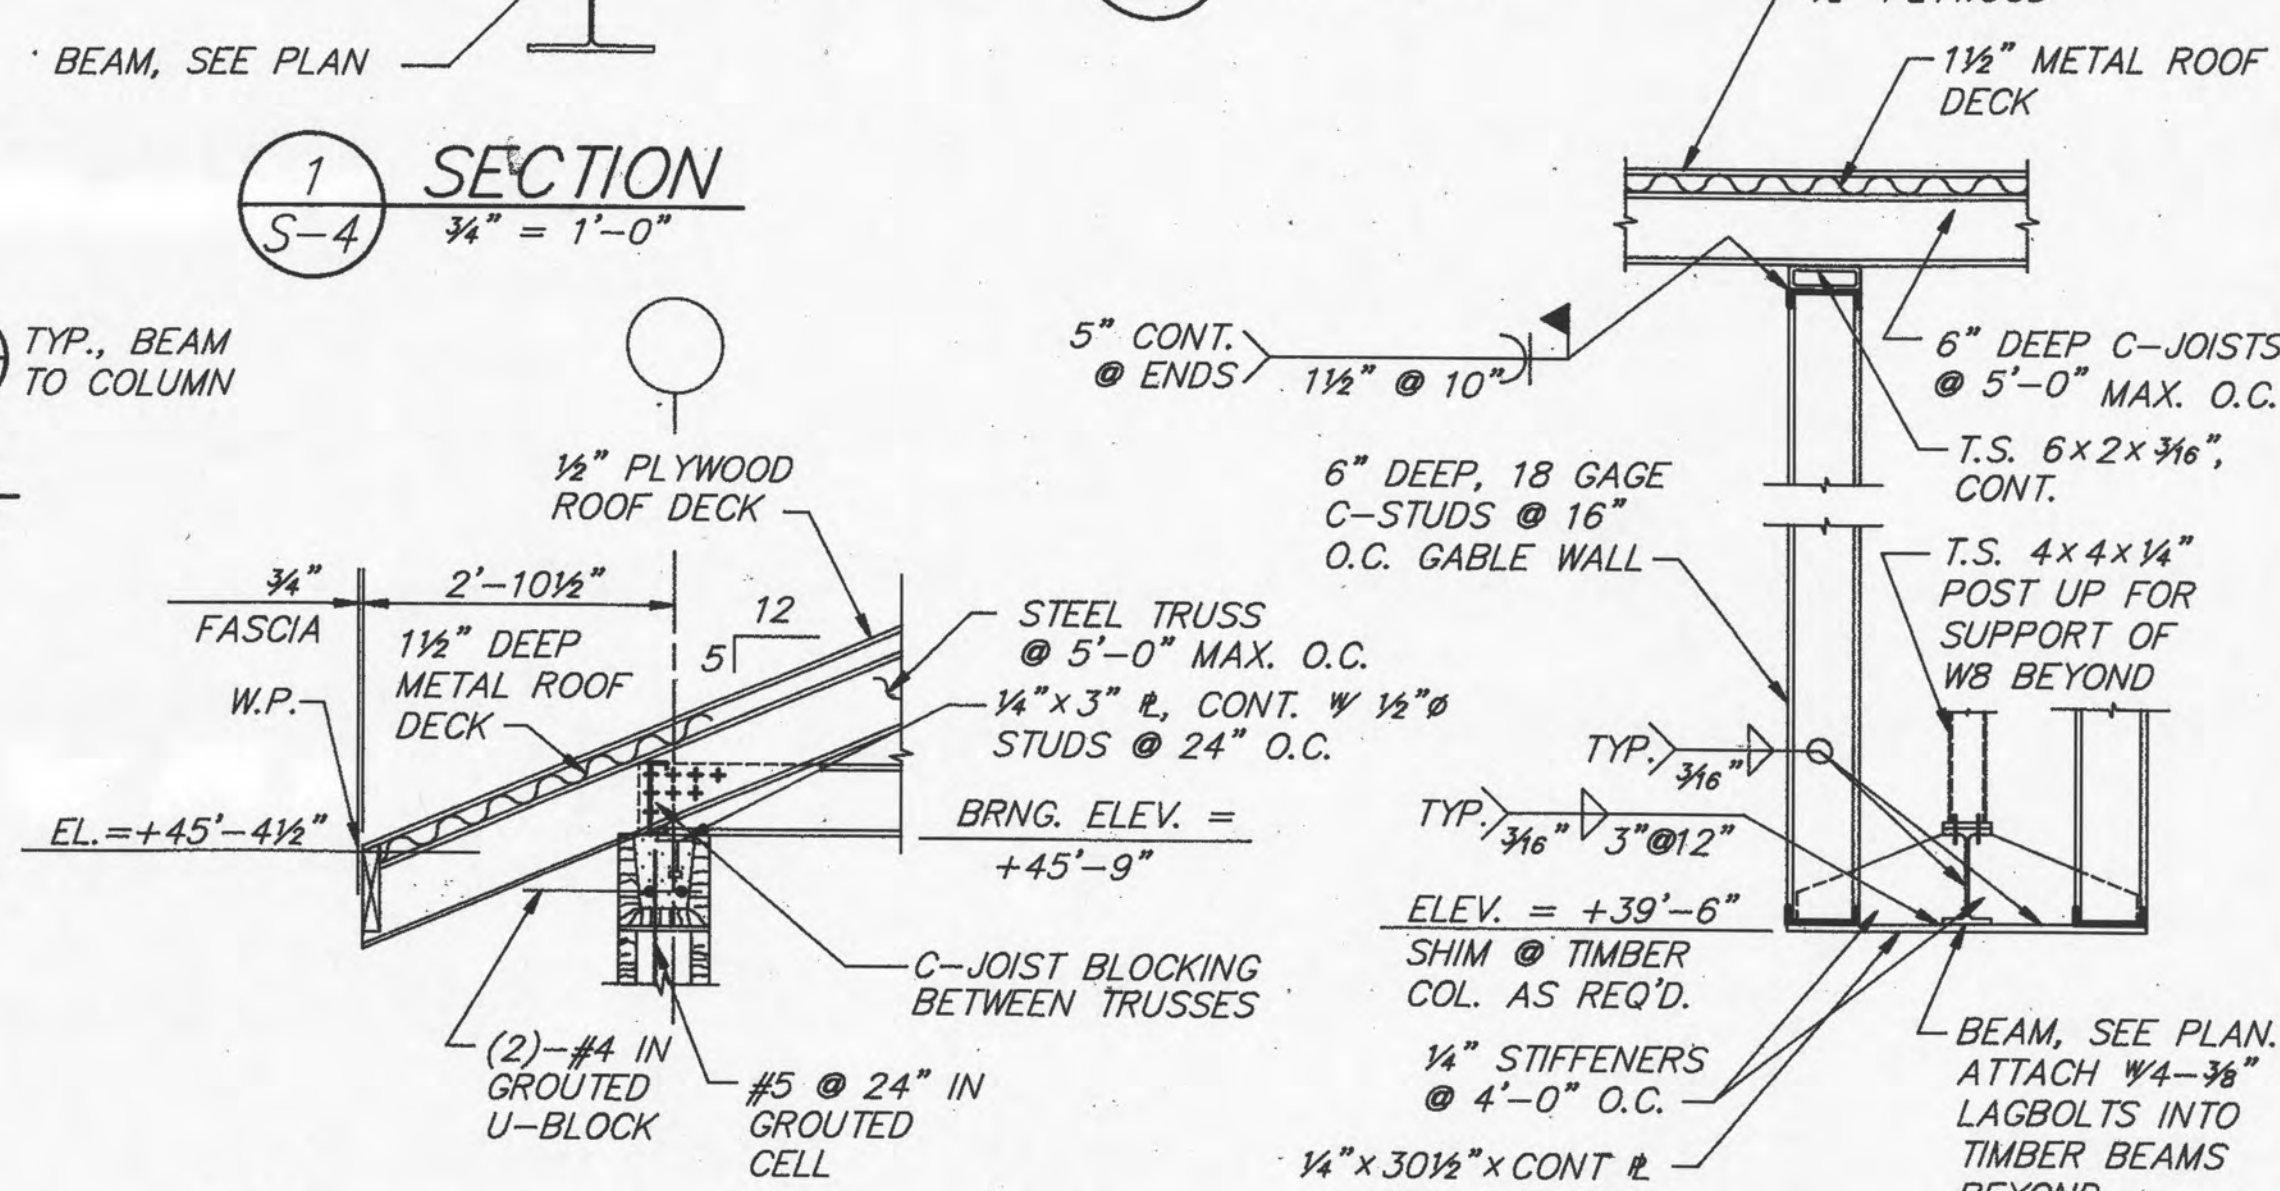

SECTION
3/4" = 1'-0"

SECTION
 $\frac{3}{4}" = 1'-0"$

ROOF FRAMING PLAN


$\frac{1}{8}'' = 1'-0''$ ** - PROVIDE (4)-#6 IN TWO END CELLS
OF WALL. LAP 40# AS REQ'D & DOWEL
INTO FTG. BELOW.

FABRICATED STEEL TRUSS NOTES

1. TRUSSES SHALL BE SPACED AS SHOWN ON THE PLANS.
2. SEE PLANS FOR TRUSS LOCATIONS AND SPANS.
3. ROOF TRUSS DESIGN LOADS SHALL BE AS FOLLOWS:


TOP CHORD LIVE LOAD:	20 PSF
TOP CHORD DEAD LOAD:	15 PSF
BOTTOM CHORD DEAD LOAD:	15 PSF

90 MPH BASIC WIND SPEED WITH LOADINGS IN ACCORDANCE WITH SBC.
4. ACTUAL TRUSS SPACING SHALL BE USED TO DETERMINE UNIFORM LOADS PER FOOT.
5. TRUSSES SHALL BE DESIGNED AND FABRICATED BY THE CONTRACTOR.
6. CONFIGURATION AND SIZE OF WEB MEMBERS SHALL BE DETERMINED BY THE TRUSS FABRICATOR; HOWEVER, THE FABRICATOR SHALL COORDINATE THE WEB MEMBER CONFIGURATION WITH THE REQUIREMENTS OF THE MECHANICAL DRAWINGS, SUCH THAT ADEQUATE OPENING IS PROVIDED FOR MECHANICAL UNITS AND DUCTS.
7. SHOP DRAWINGS AND COMPLETE DESIGN CALCULATIONS FOR TRUSSES SHALL BE SUBMITTED FOR APPROVAL PRIOR TO FABRICATION. DESIGN AND SHOP DRAWINGS SHALL CARRY THE SEAL OF AN ENGINEER REGISTERED IN THE STATE OF TENNESSEE.
8. TOP CHORD DEAD LOAD SHOWN ABOVE INCLUDES 3 PSF FOR TRUSS SELF-WEIGHT.
9. MAXIMUM LIVE LOAD DEFLECTION FOR ROOF TRUSSES = $L/360$.
10. LOADS ABOVE SHALL BE UTILIZED IN THE DESIGN OF GIRDER TRUSSES AS REQUIRED.
11. PERMANENT BRACING, AS REQUIRED BY STRUCTURAL DESIGN OF THE TRUSSES, AND PERMANENT BRACING AS REQUIRED FOR STABILITY OF THE TRUSS SYSTEM UNDER ALL GRAVITY AND LATERAL LOADINGS, SHALL BE INDICATED AND FULLY DETAILED ON THE SHOP DRAWINGS.
12. THE CONTRACTOR SHALL PROVIDE ADEQUATE TEMPORARY BRACING FOR THE TRUSSES DURING ERECTION.
13. TRUSS DESIGN SHALL ACCOUNT FOR LOAD IMPOSED UPON TRUSSES BY WEIGHT OF MECHANICAL UNITS.

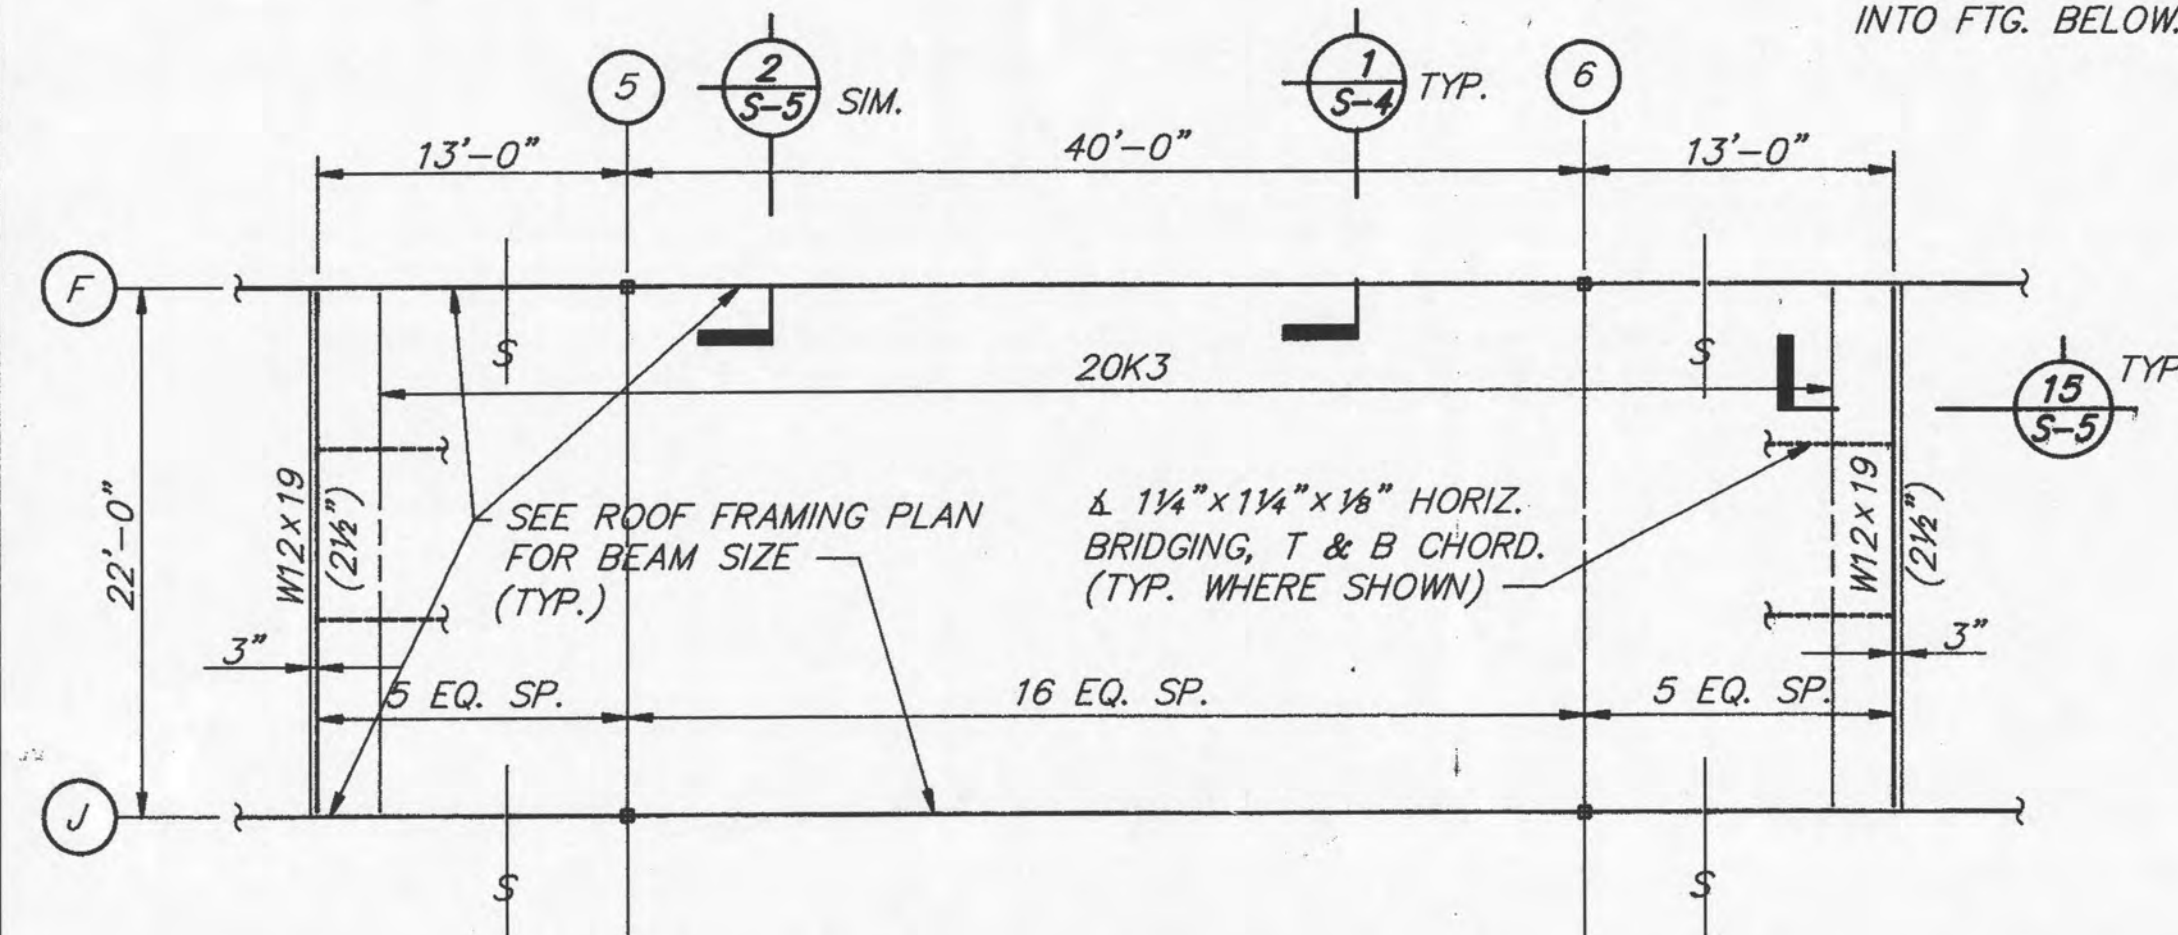


MEZZANINE FRAMING PLAN


$1/8" = 1'-0"$ TOP OF MEZZANINE SLAB
ELEV. = +46'-2 1/2"

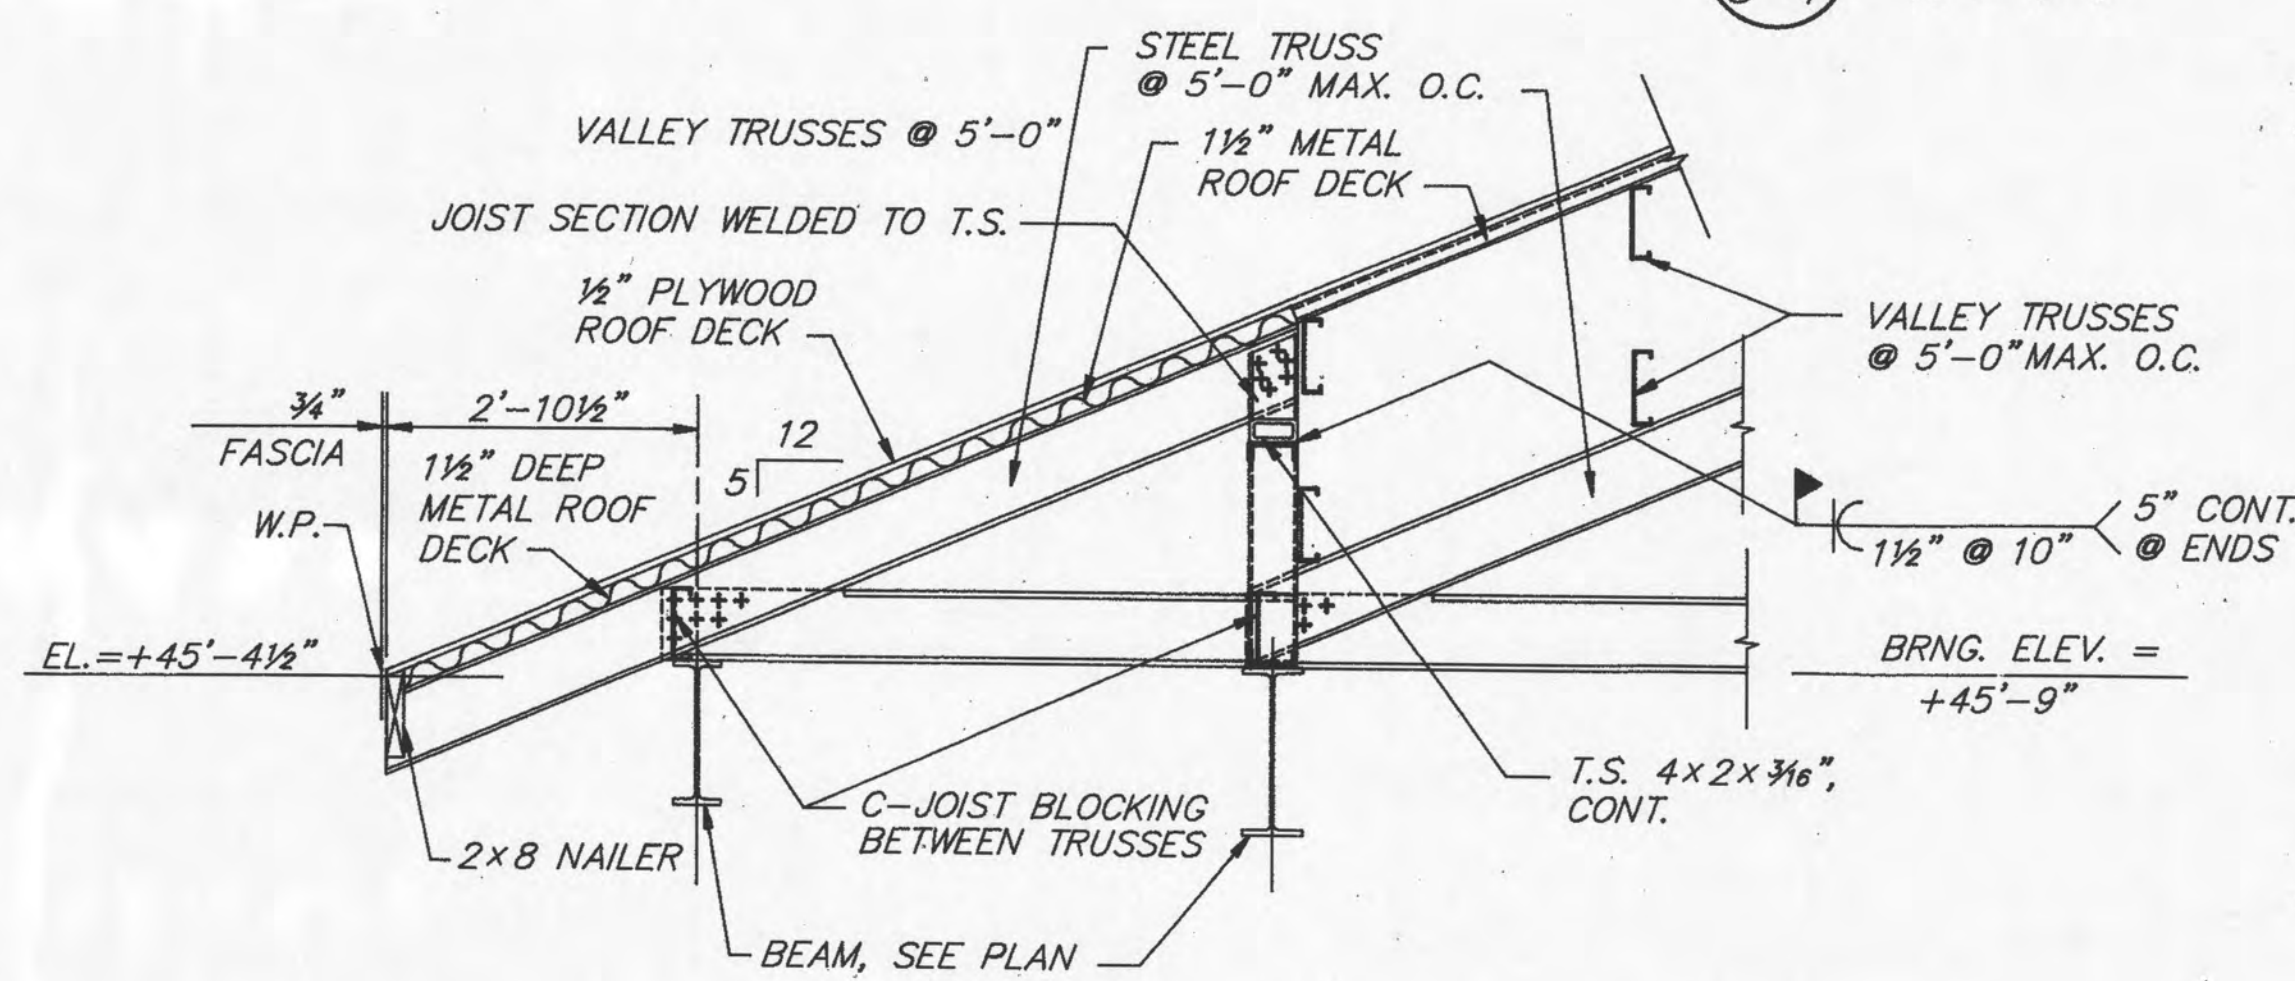


5 SECTION
S-4 $\frac{3}{4}" = 1'-0"$

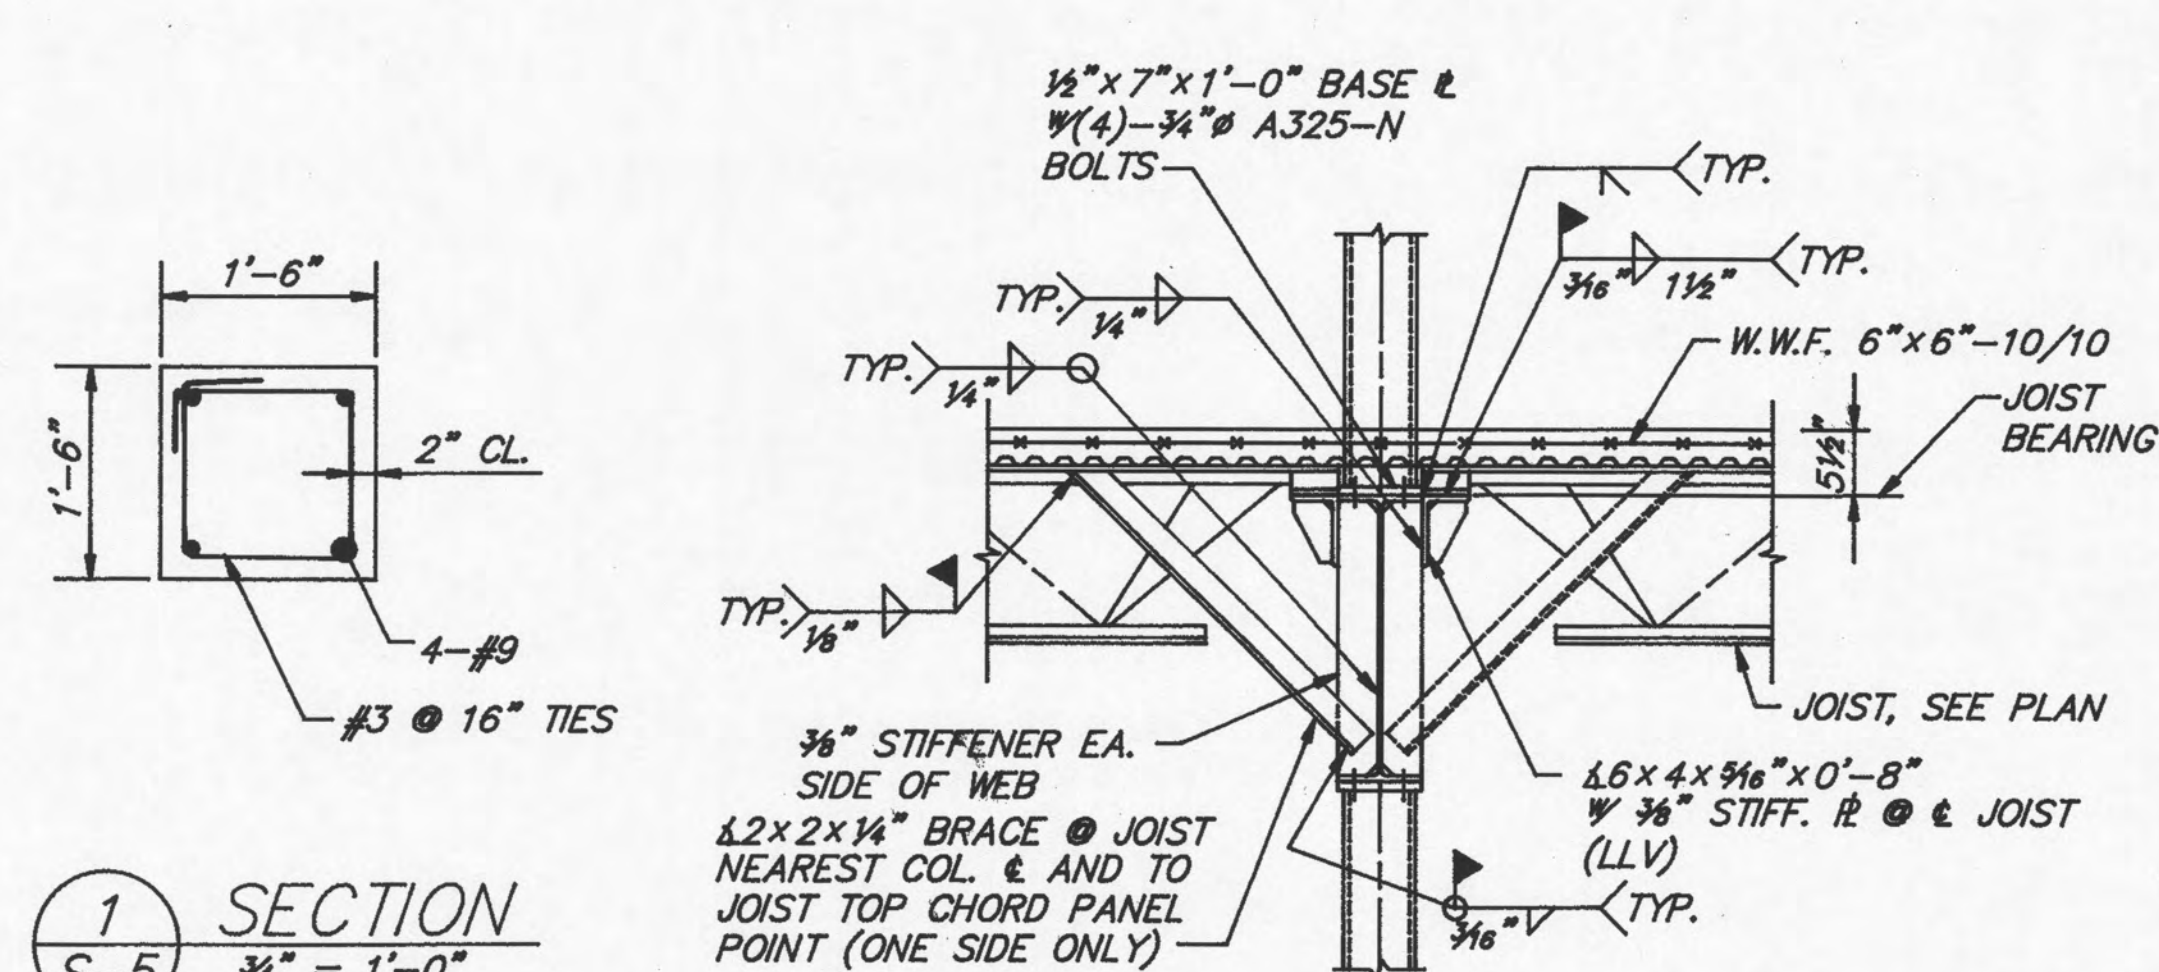


SECTION 2 S-5
1/4" = 1'-0"

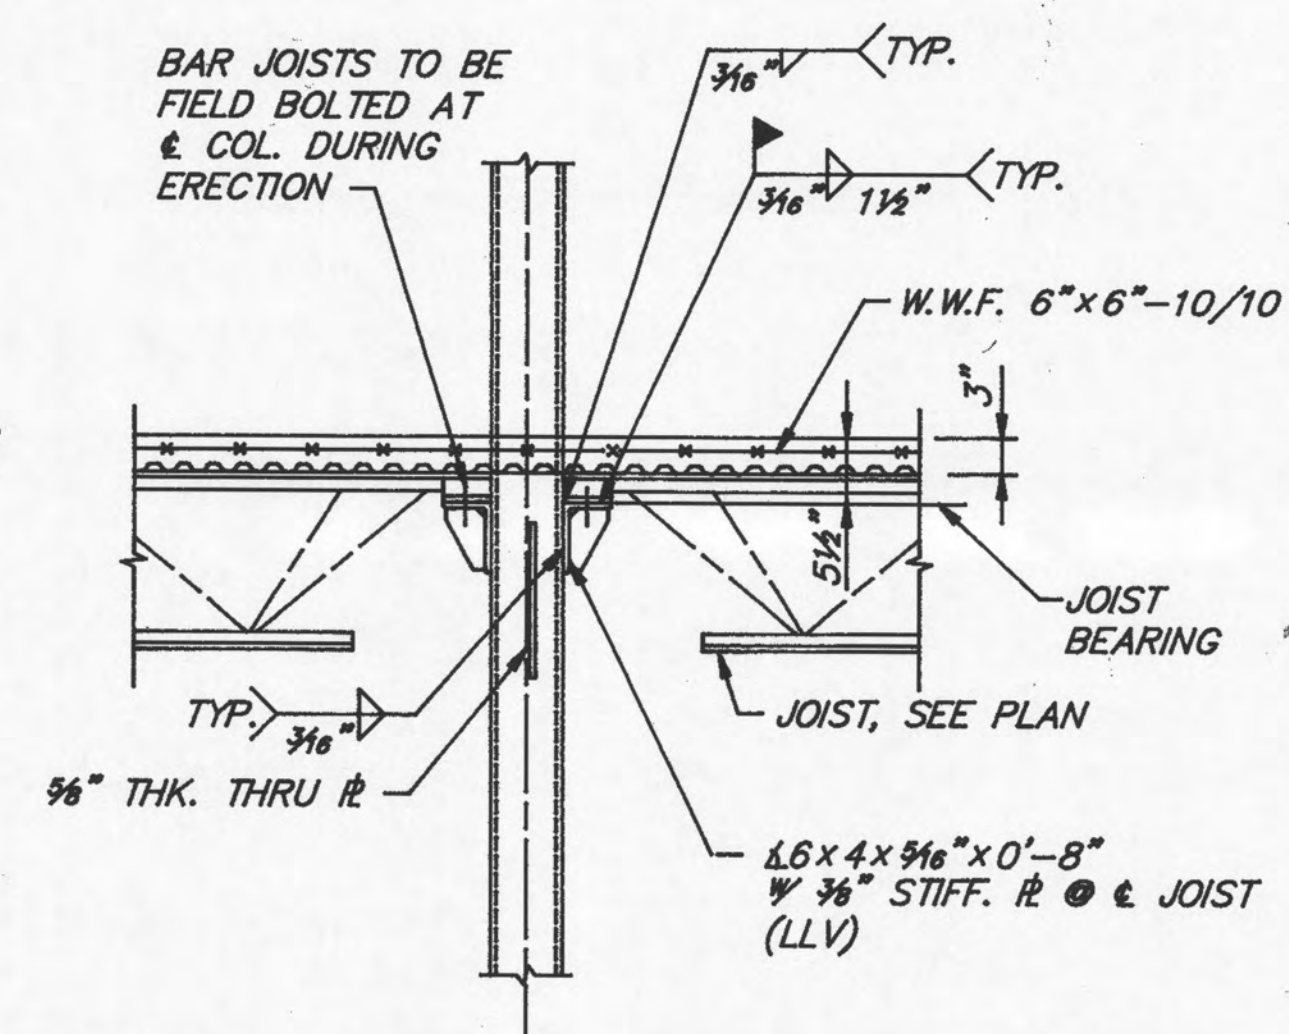


SECTION 3 S-5
1/4" = 1'-0"

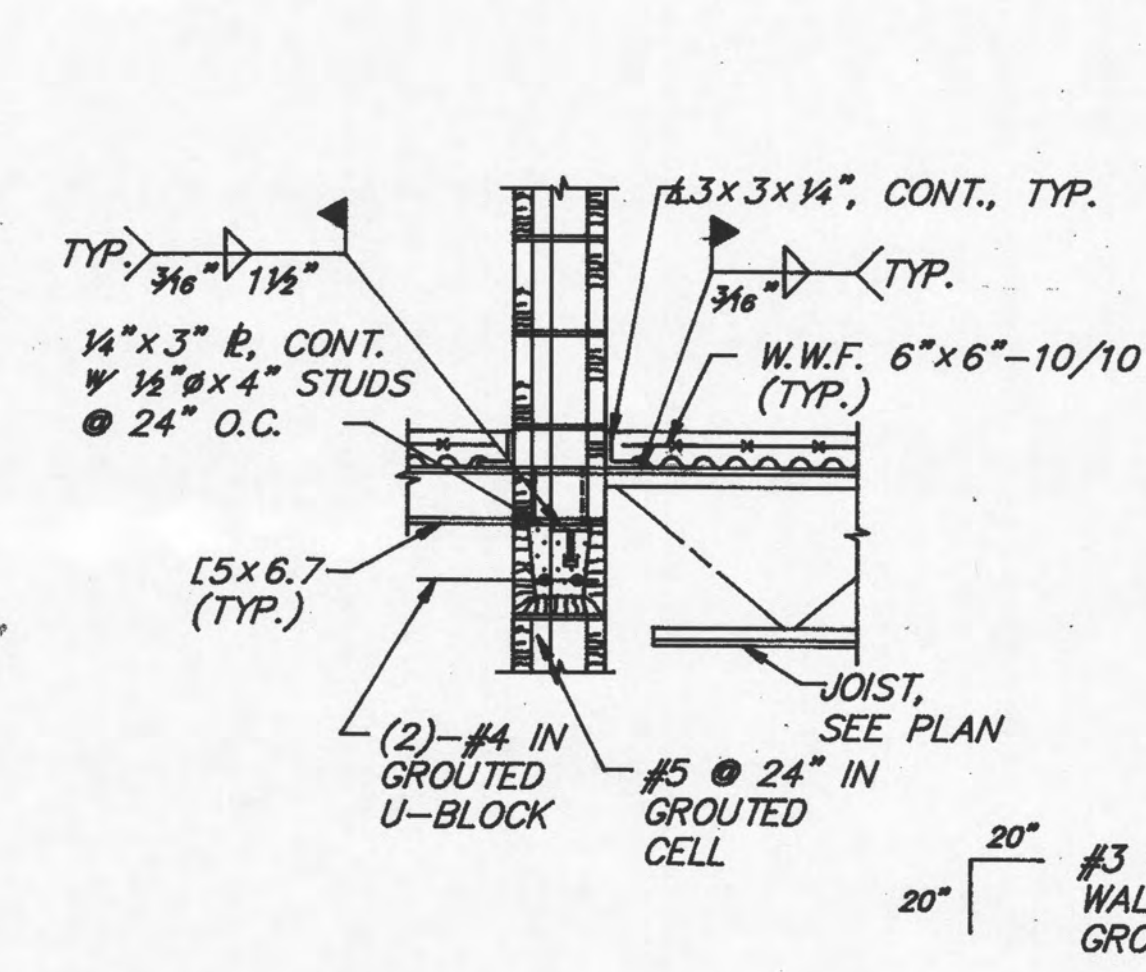


SECTION 4 S-5
1/4" = 1'-0"

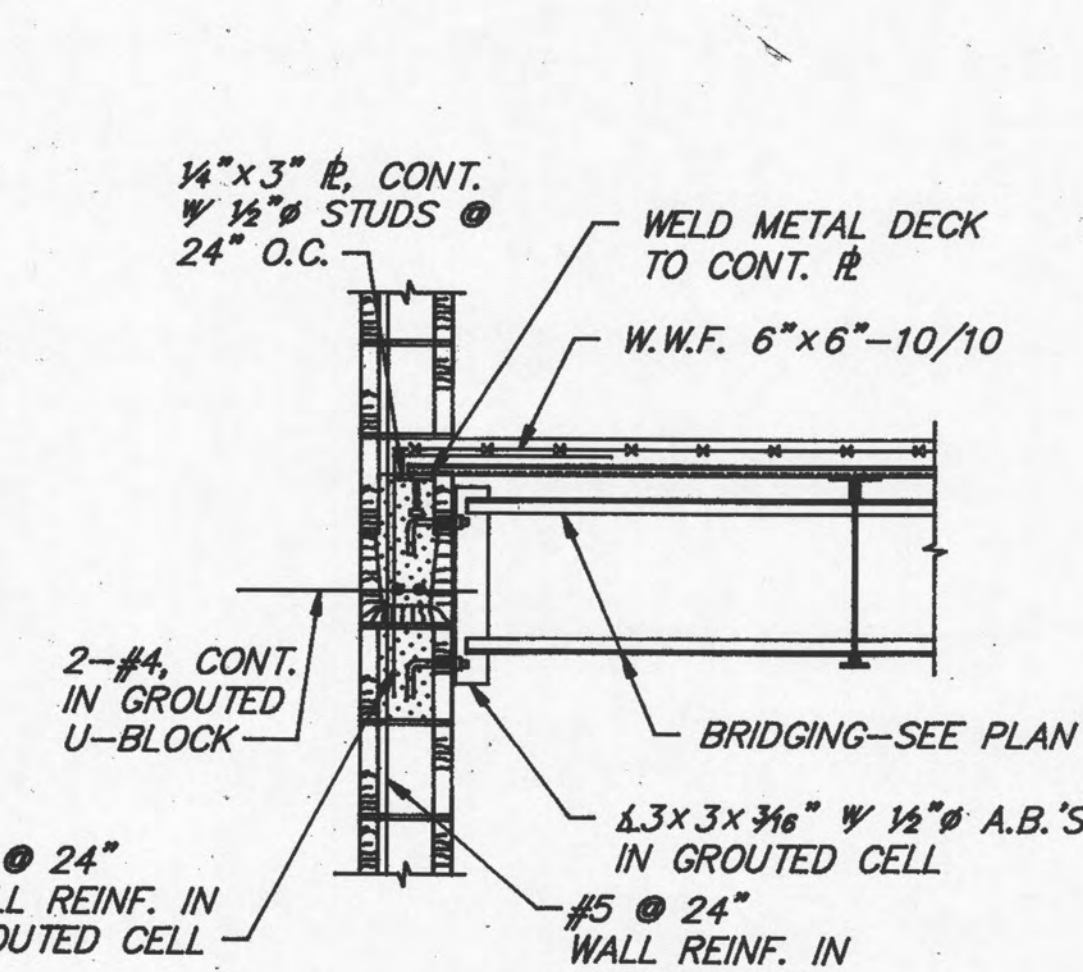


SECTION 5 S-5
1/4" = 1'-0"

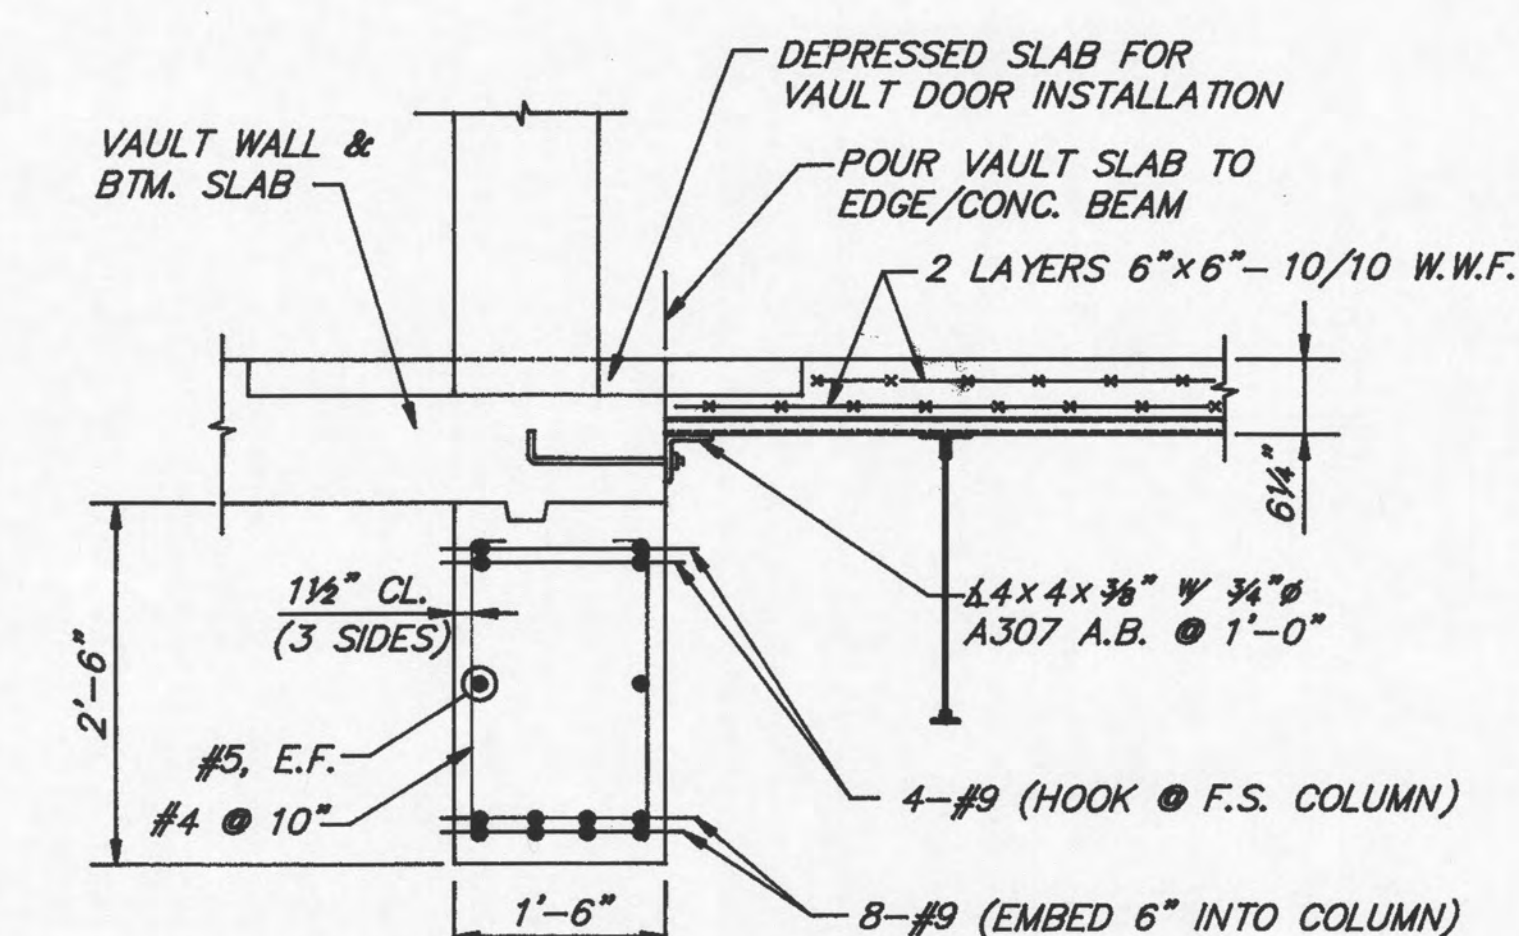


SECTION 6 S-5
1/4" = 1'-0"

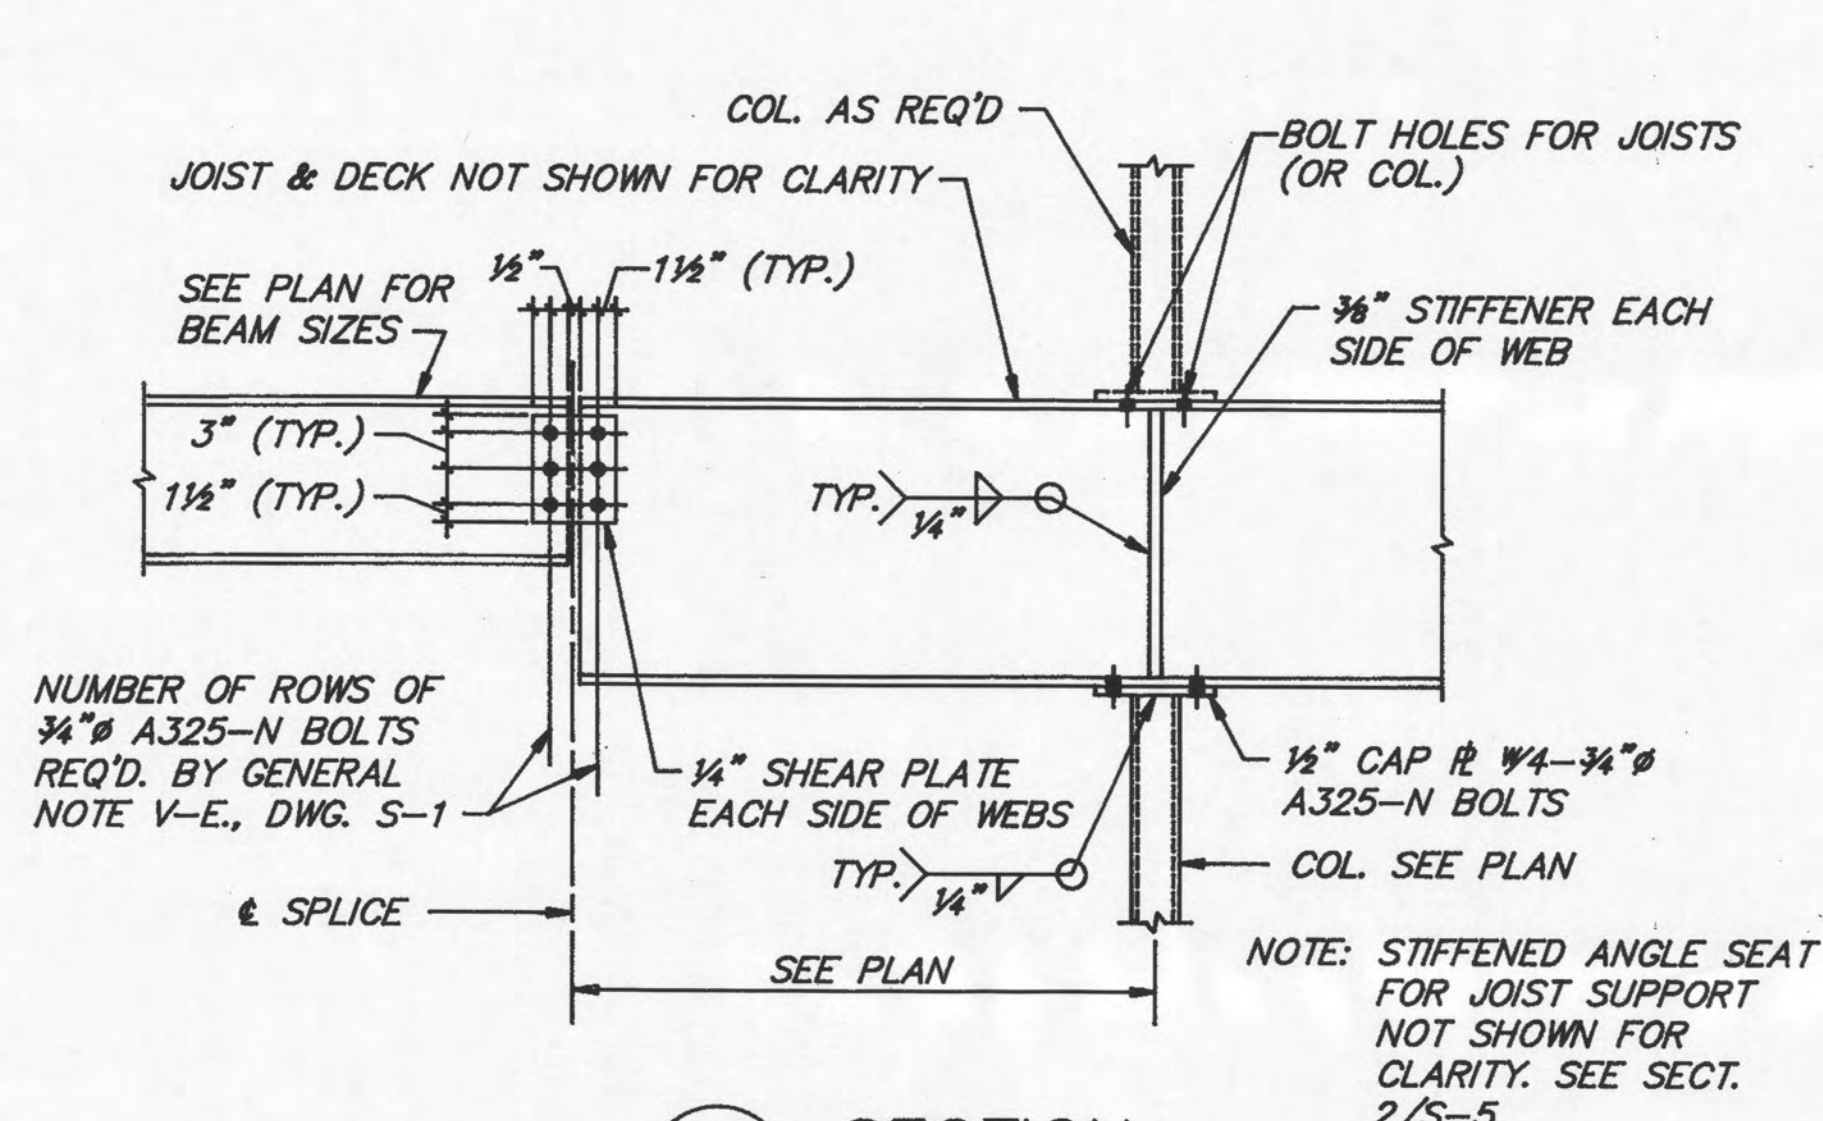


SECTION 7 S-5
1/4" = 1'-0"

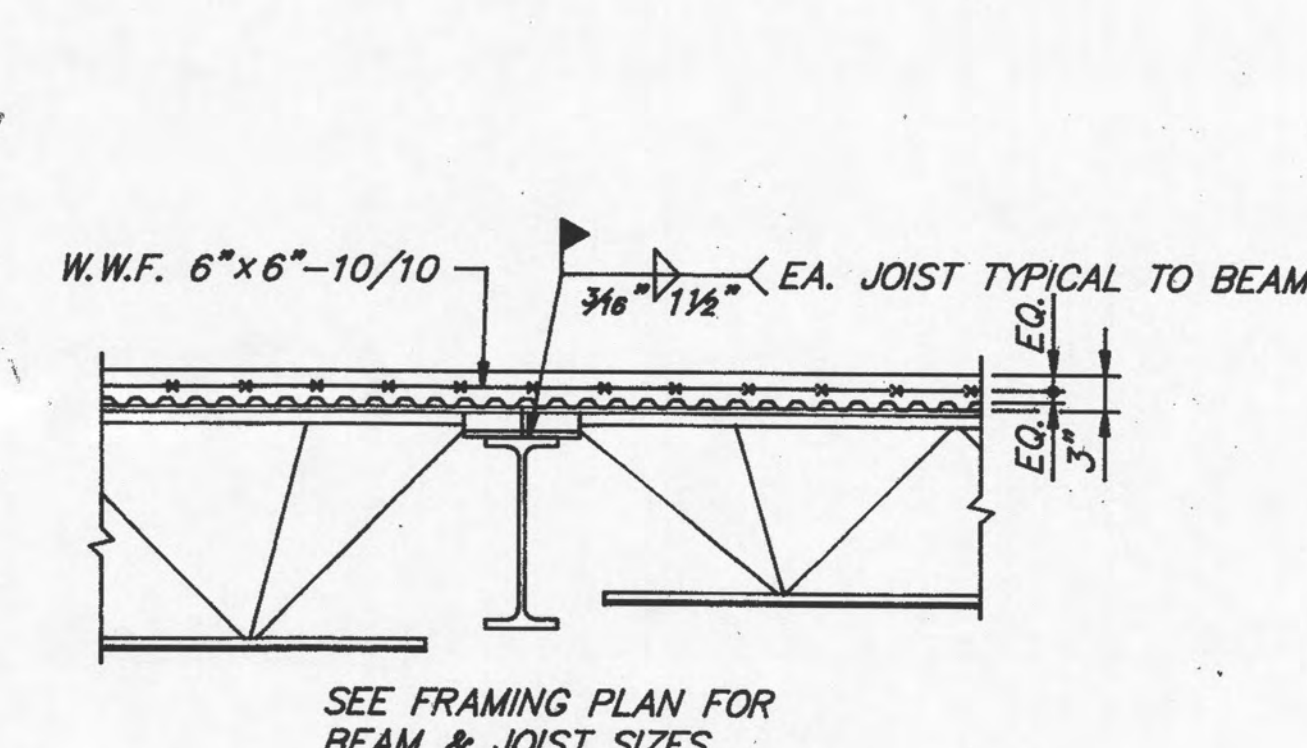


SECTION 8 S-5
1/4" = 1'-0"

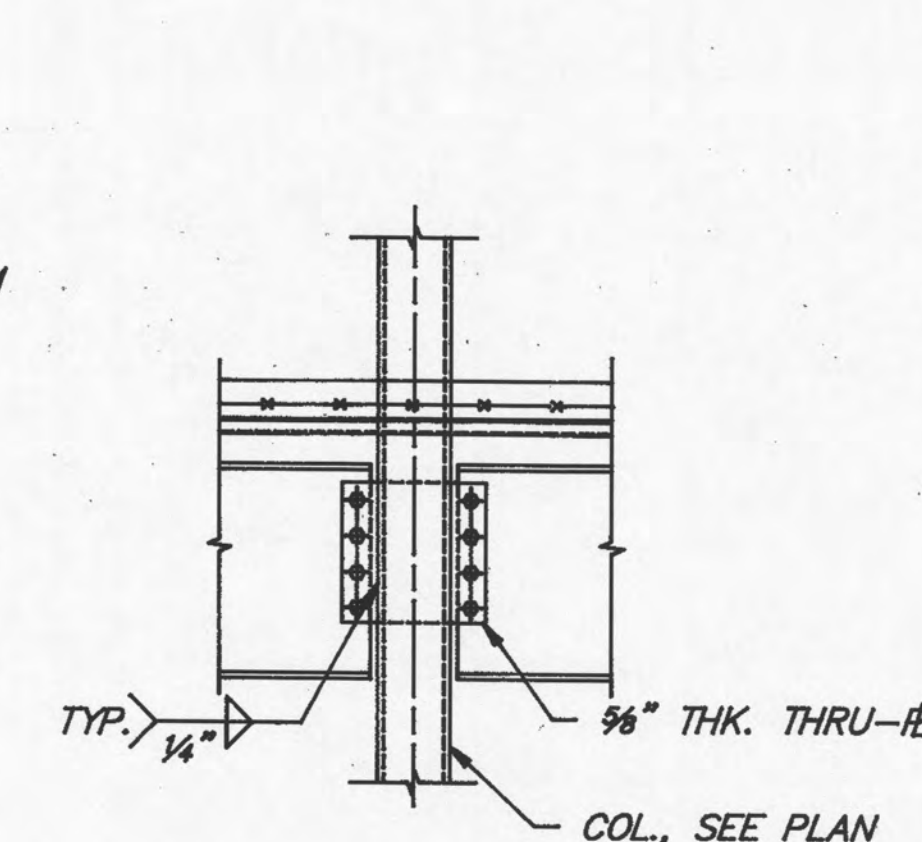


SECTION 9 S-5
1/4" = 1'-0"

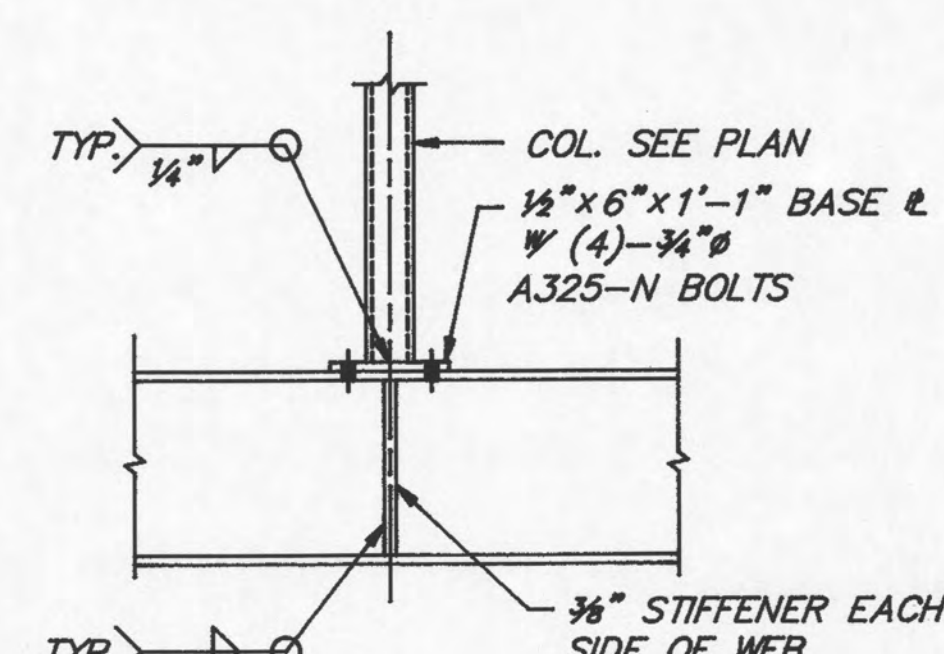


SECTION 10 S-5
1/4" = 1'-0"

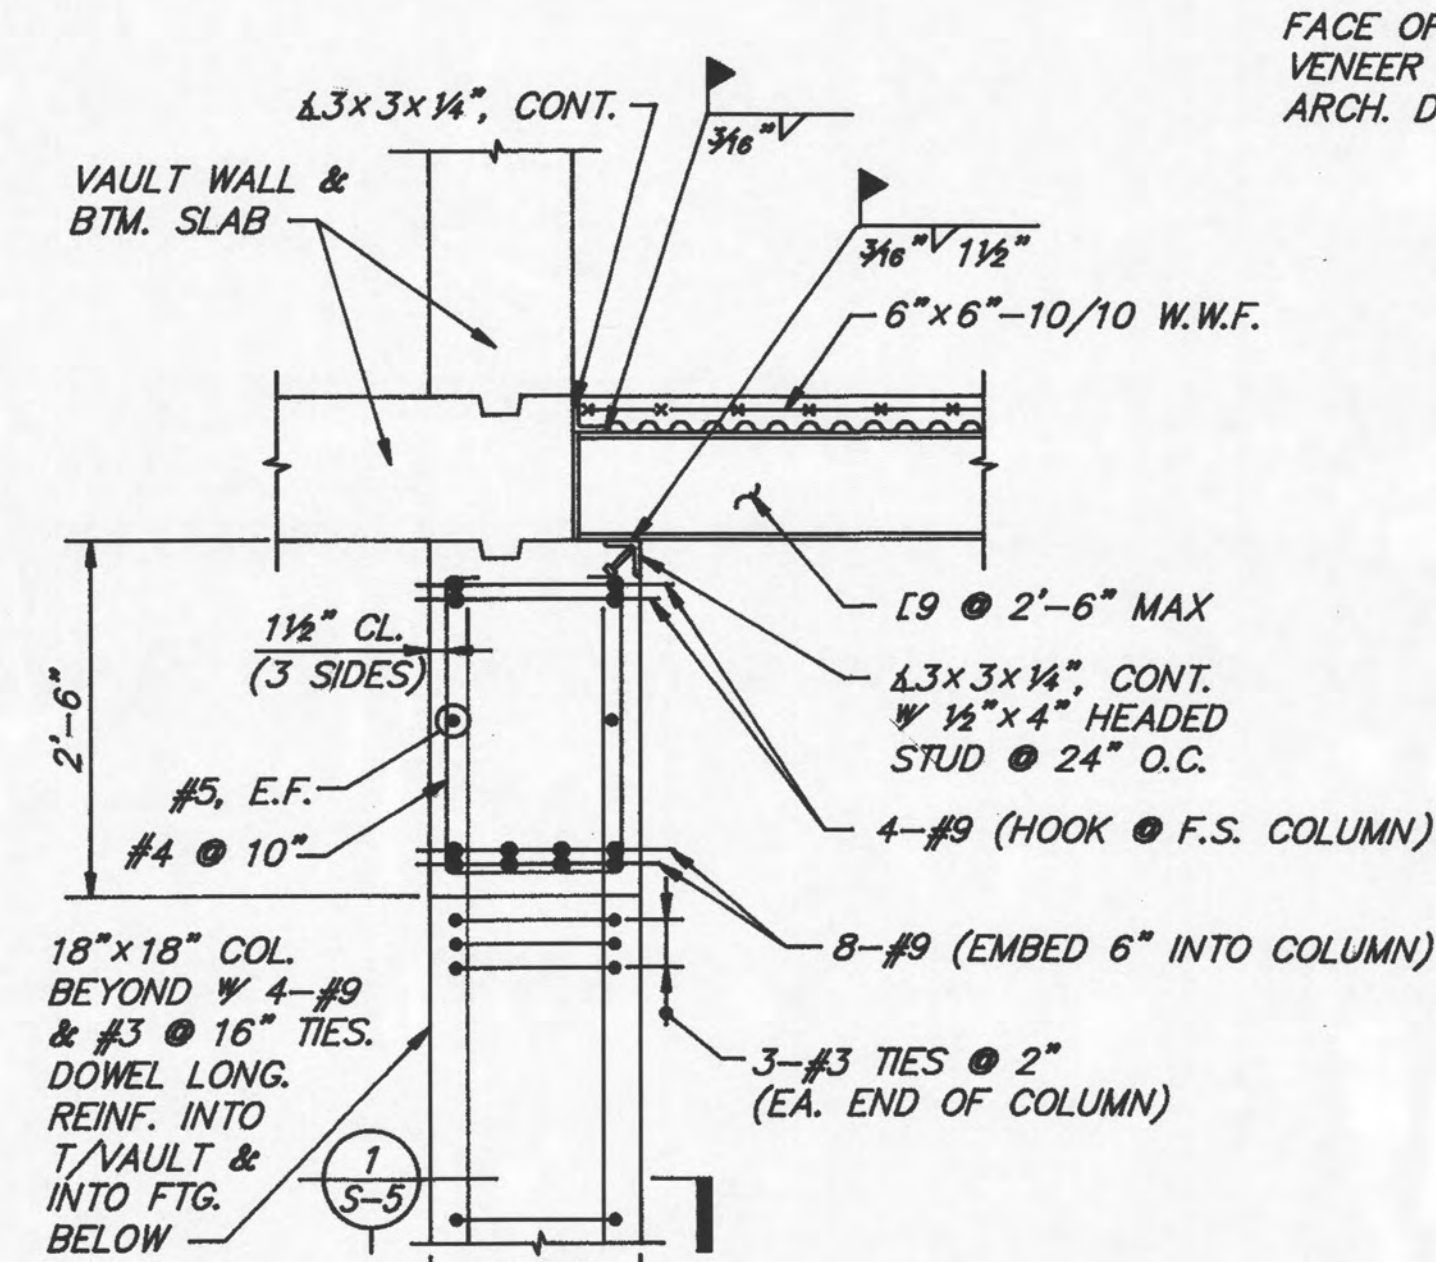


SECTION 11 S-5
1/4" = 1'-0"

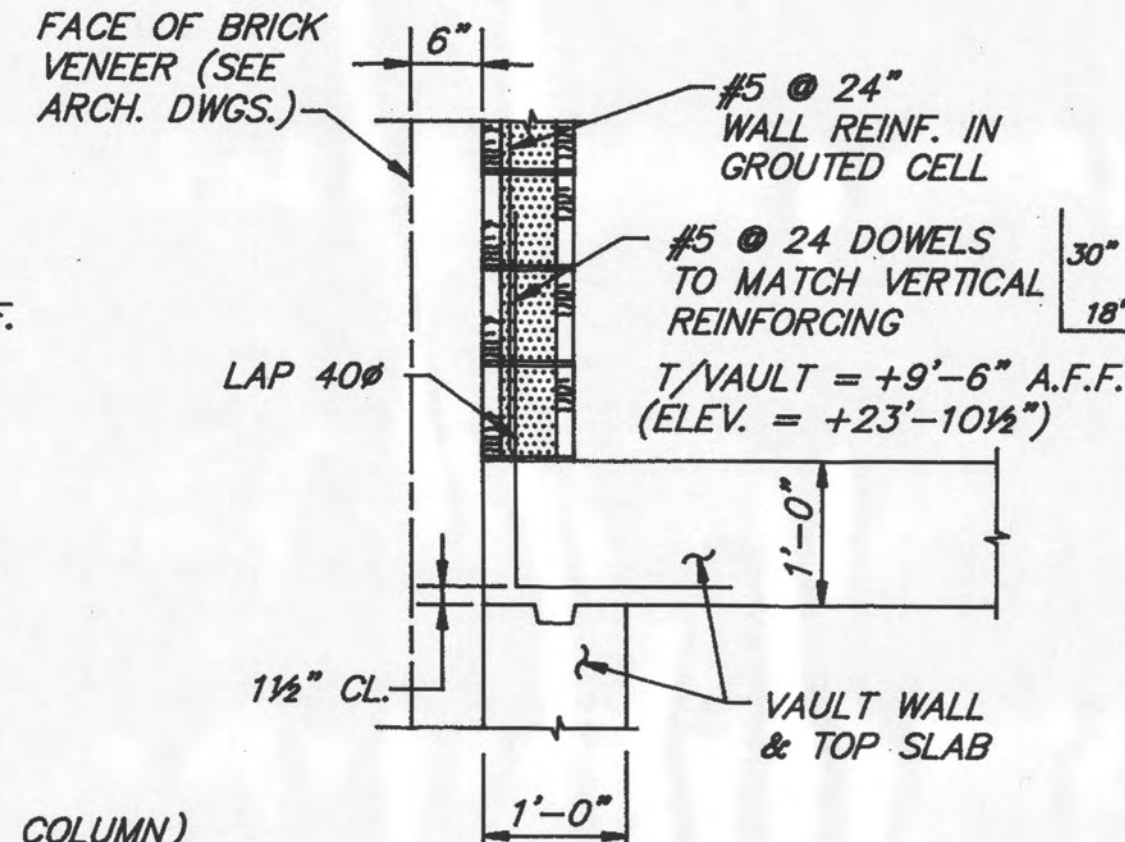


SECTION 12 S-5
1/4" = 1'-0"

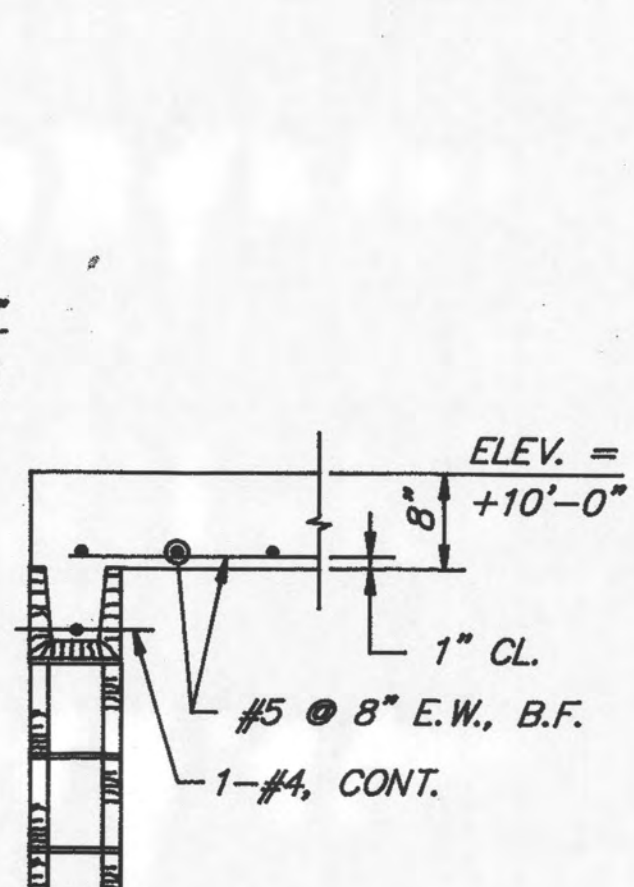

SECTION 13 S-5
1/4" = 1'-0"

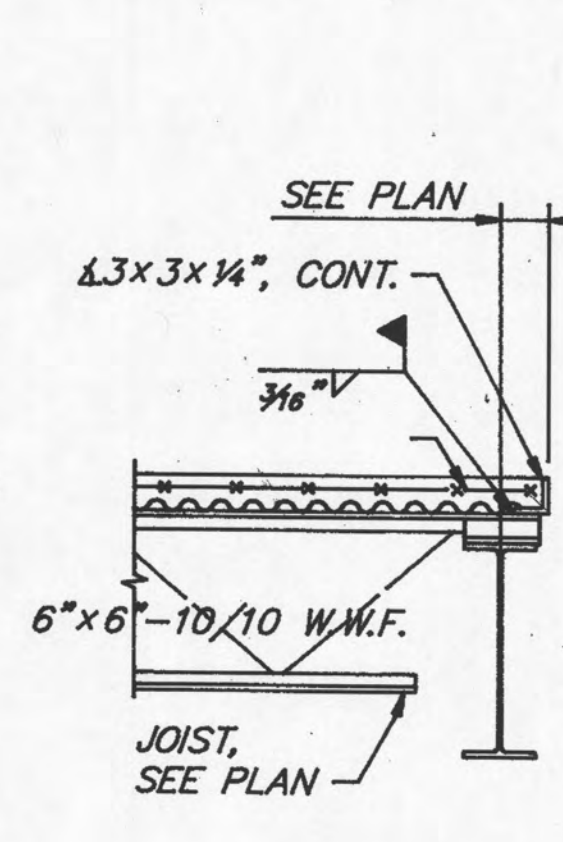

SECTION 14 S-5
1/4" = 1'-0"

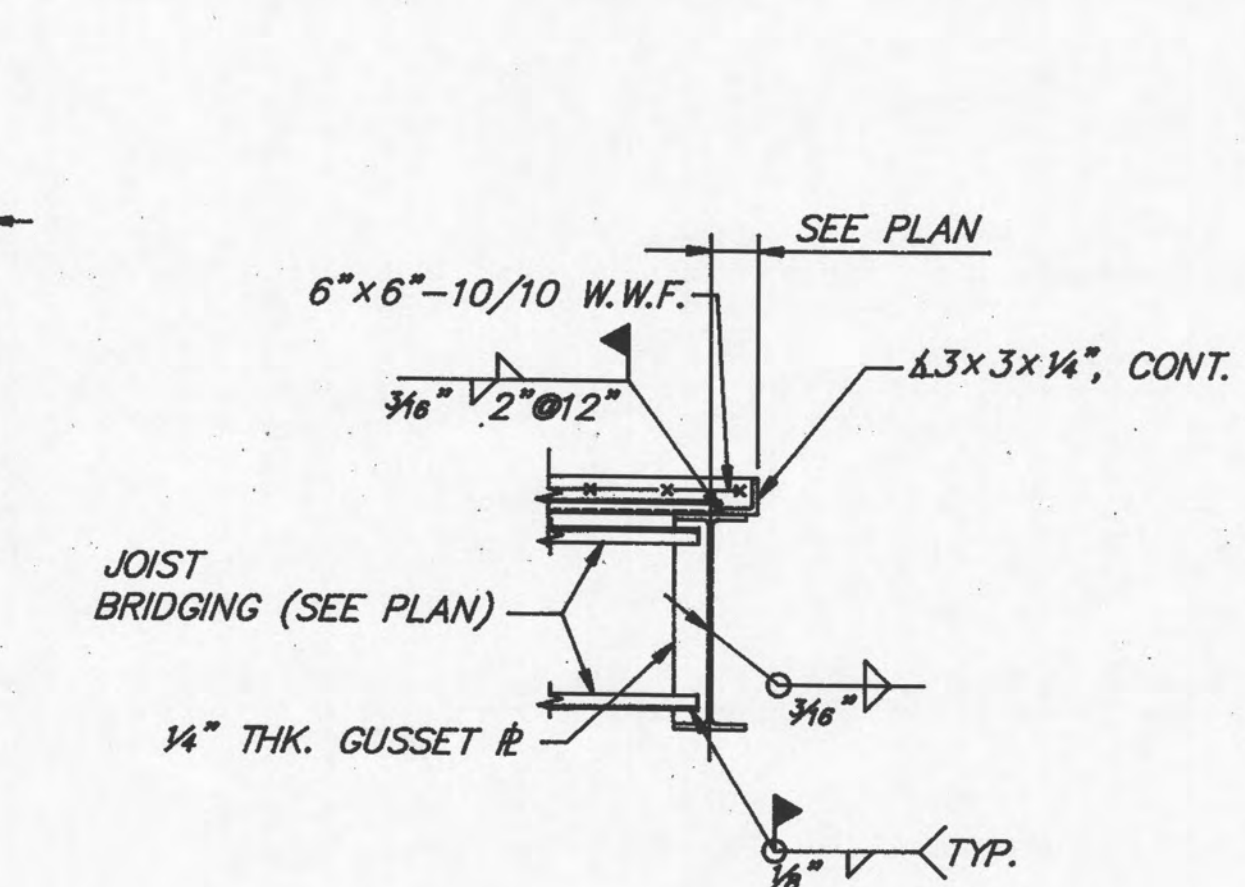

SECTION 15 S-5
1/4" = 1'-0"

DATE	3-8-8
BY	CR
CHECKED	CR
APPROVED	CR

Consultants
Designers
Construction Managers

Concepts

147725 0800
Riverside, Georgia 30112

RELEASED FOR CONSTRUCTION

THESE DRAWINGS AND THE DESIGN THEREON ARE THE SOLE PROPERTY OF CONCEPTS, INC. AND ARE NOT TO BE REPRODUCED OR USED IN ANY MANNER WITHOUT THE WRITTEN AUTHORIZATION OF CONCEPTS, INC. ANY VIOLATION OF THIS NOTICE IS PROHIBITED.

5-4-82

SECTIONS AND DETAILS

A NEW MAIN OFFICE FACILITY FOR:


Bank of Roane County
HARRIMAN, TENNESSEE

SEE: JUNE 10, 1982

S-5

Sheet


d'7 specs

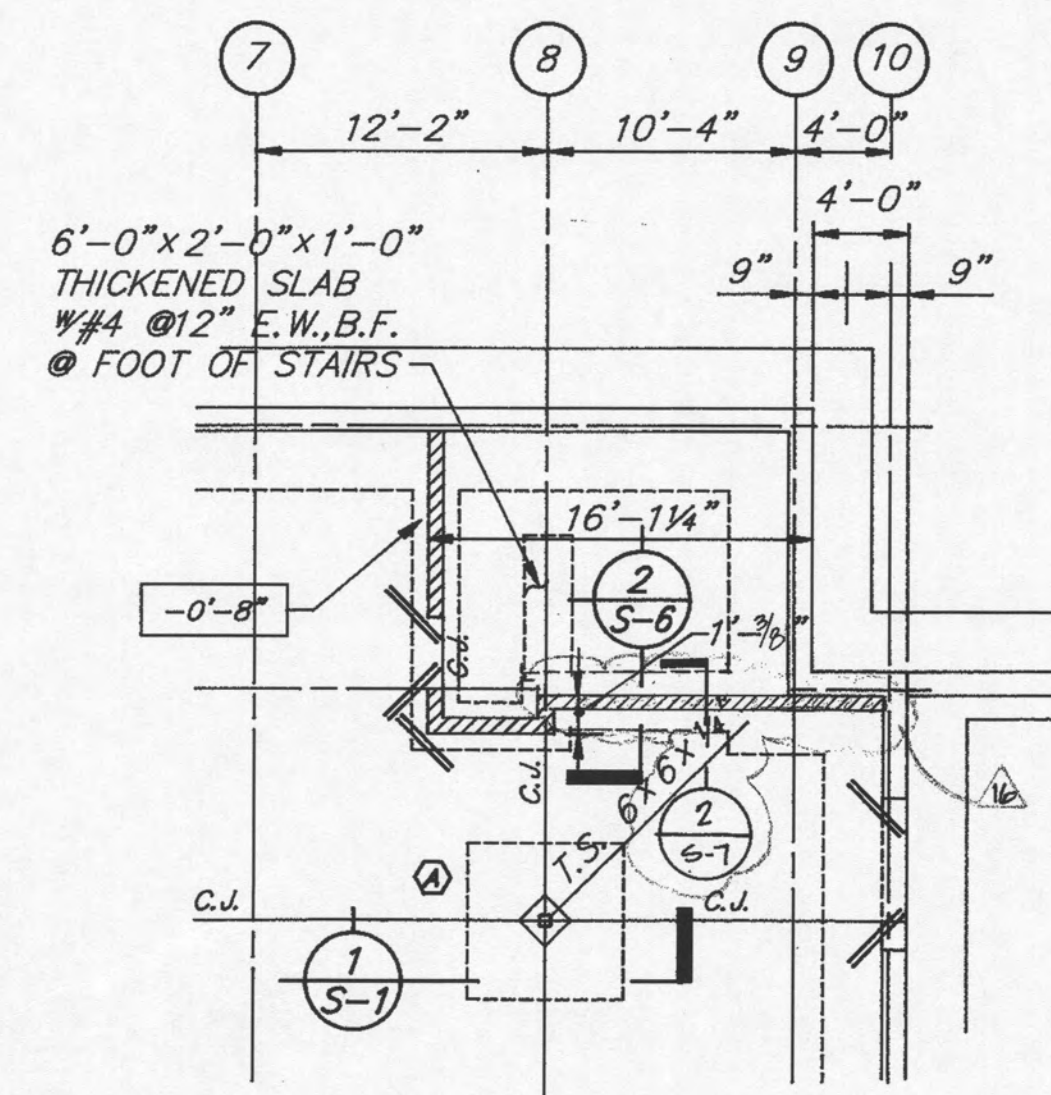

PARTIAL SLAB & FOUNDATION PLAN - LEVEL I

$1/8" = 1'-0"$ TOP OF FINISHED SLAB DATUM = $+0'-0"$


☐ — INDICATES T/FTG ELEV.

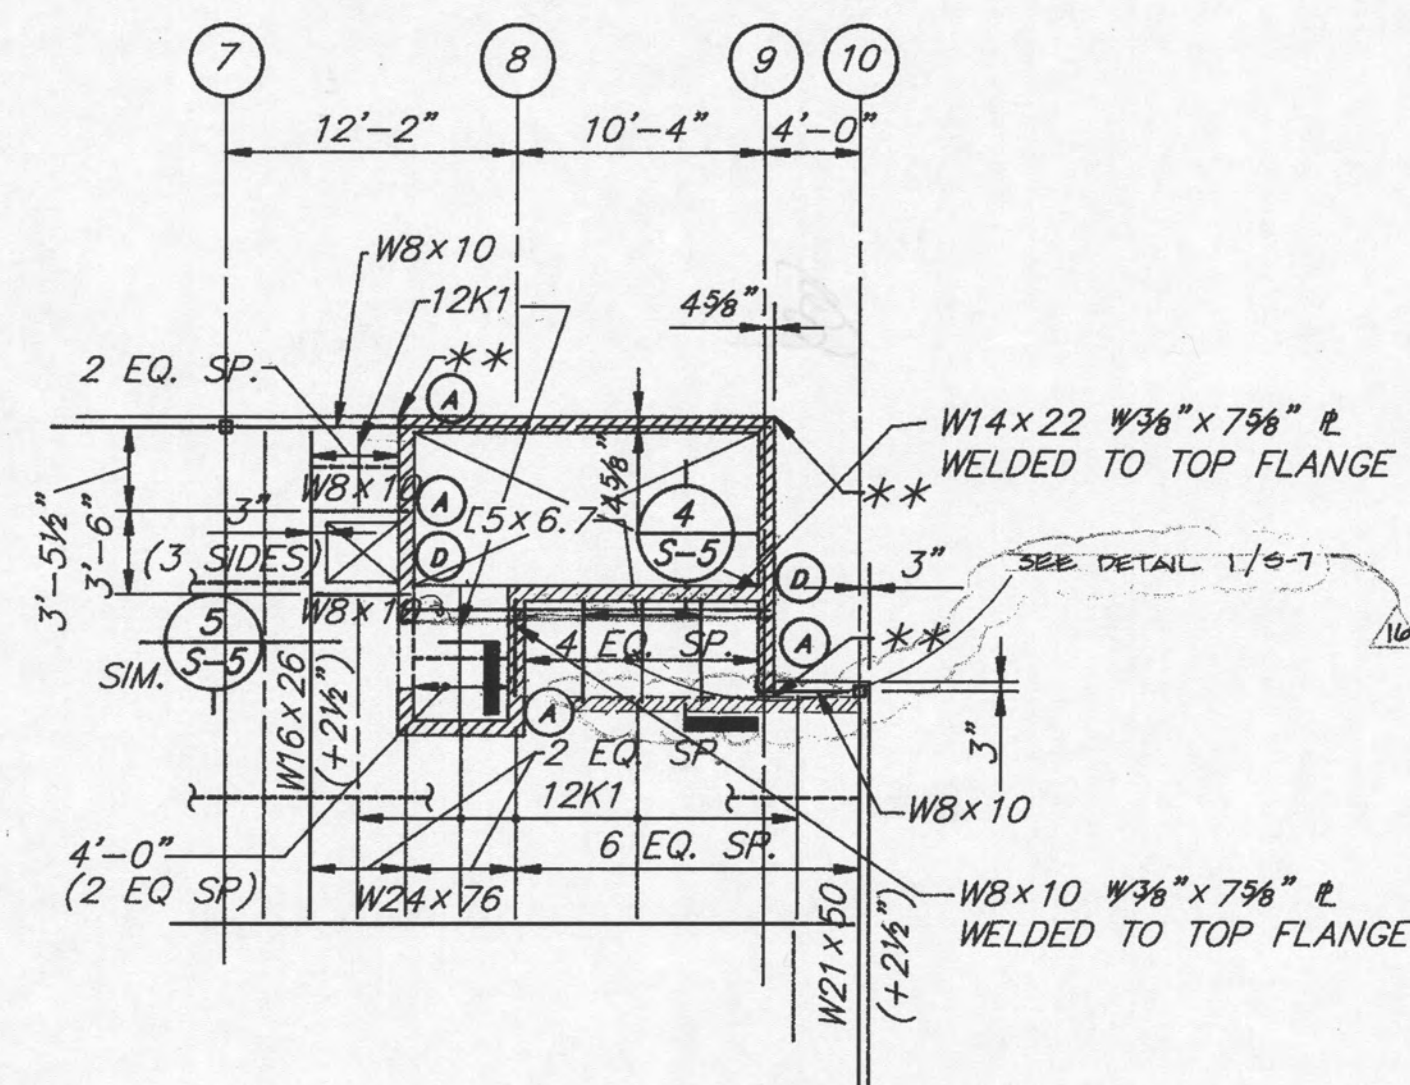

PARTIAL FLOOR FRAMING PLAN - LEVEL III

$$\frac{1}{8}'' = 1'-0''$$


T/LEVEL III SLAB ELEV. = +29'-8½"

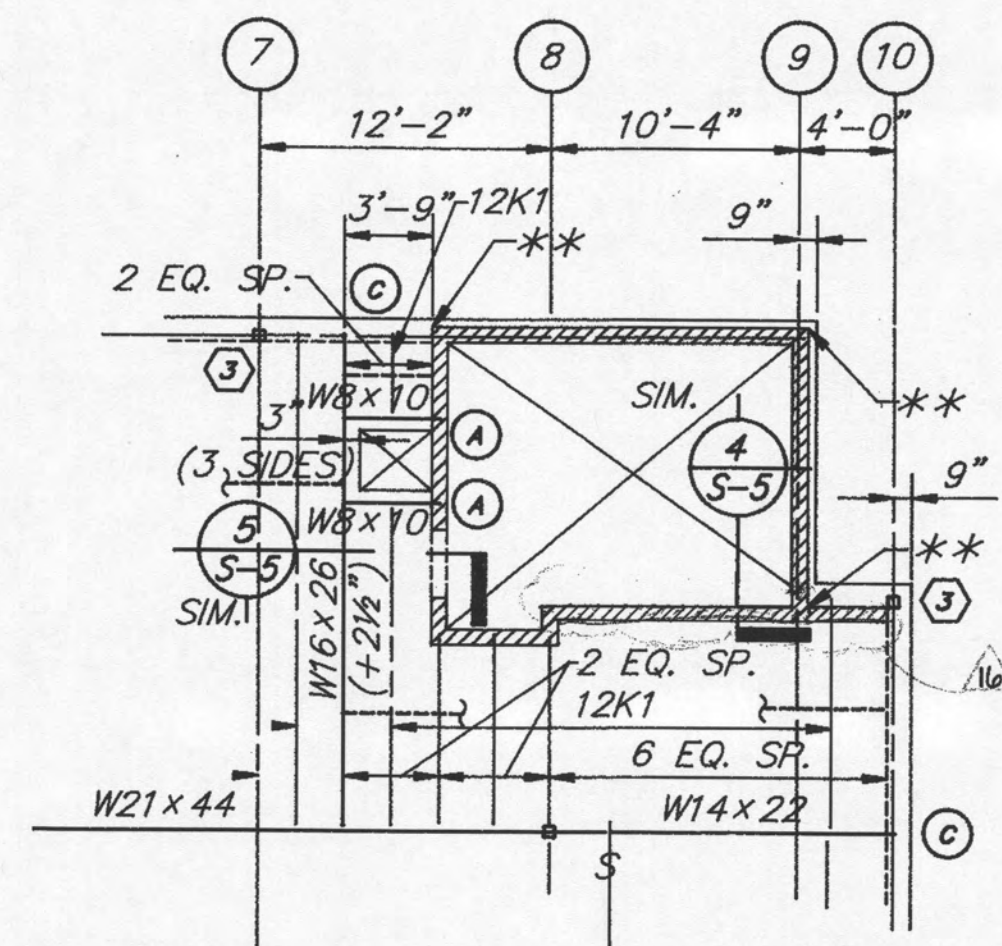


PARTIAL FLOOR FRAMING PLAN - LEVEL II

$$\frac{1}{8}'' = 1'-0''$$

T/LEVEL II SLAB ELEV. = +14'-4½", U.N.O.

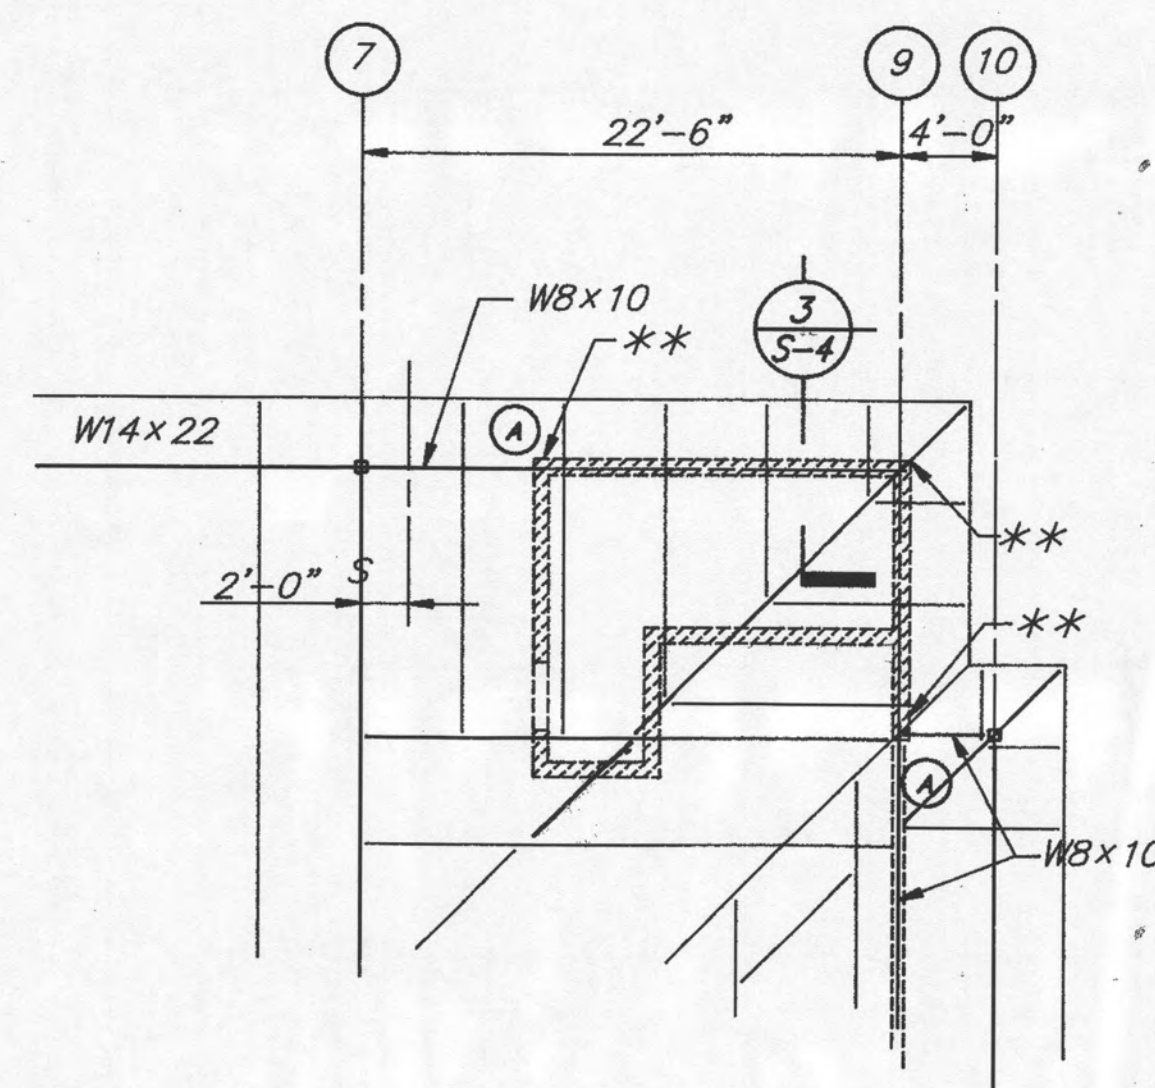


PARTIAL ROOF FRAMING PLAN
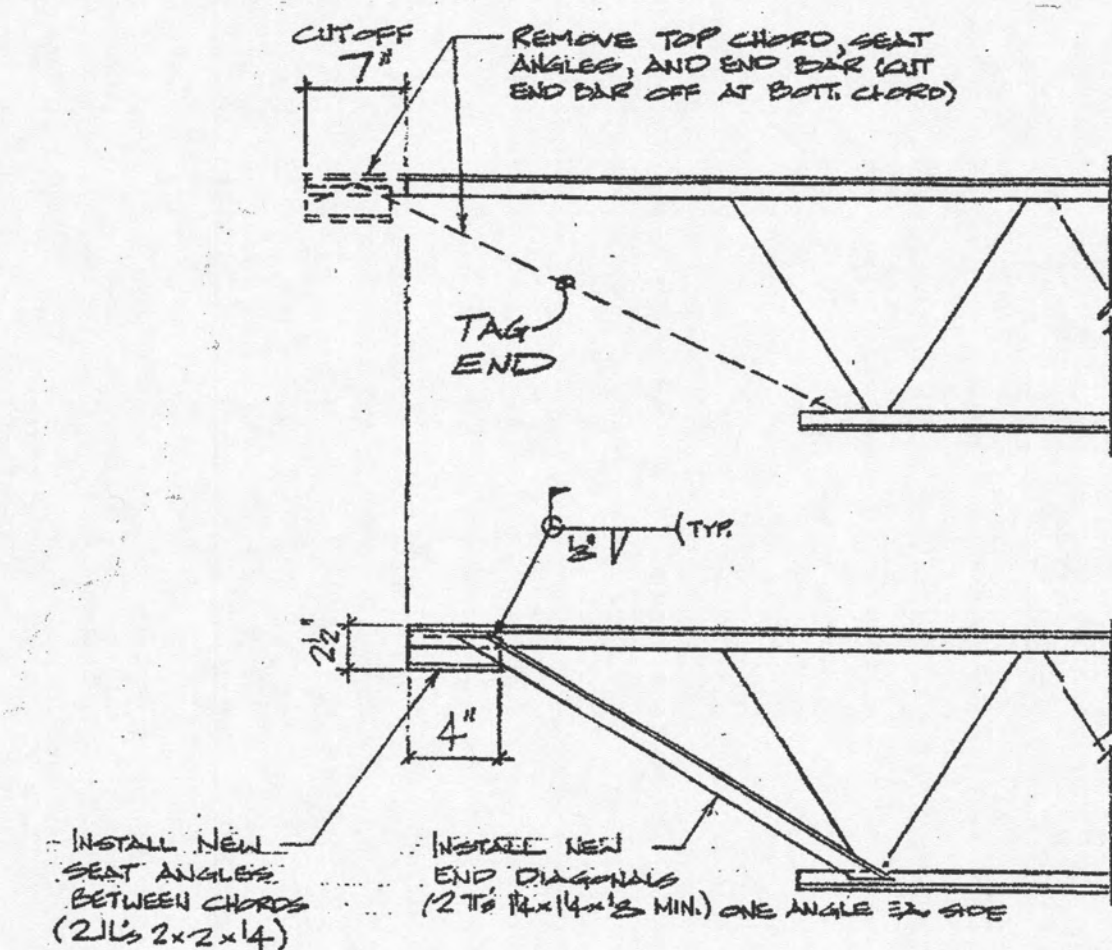
$$\frac{1}{8}'' = 1'-0''$$


1 JOIST REPAIR DETAIL

S-7 **N.T.S.**

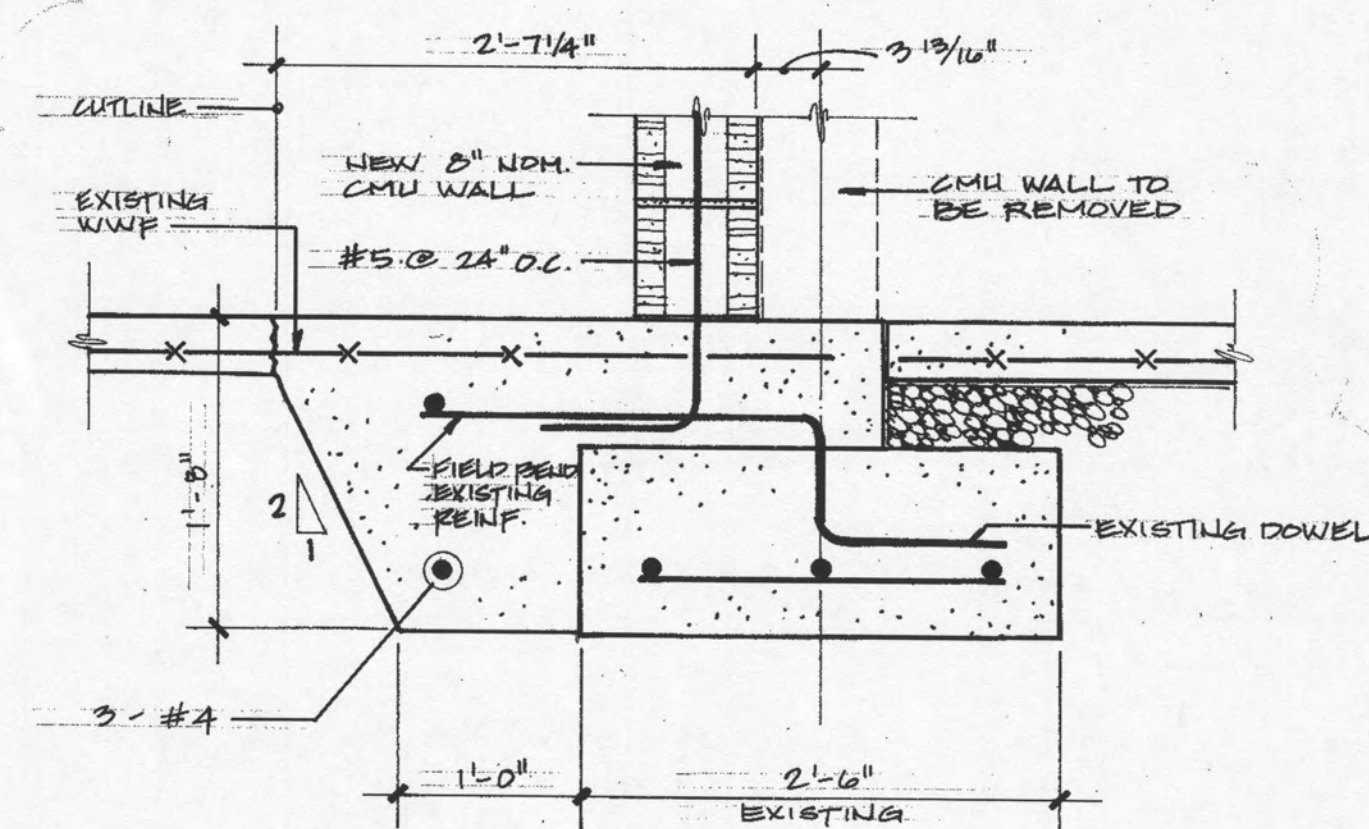

2 FOOTING DETAIL

S-7 **SCALE: 1" = 1'-0"**

References

STAIR REVISIONS

A NEW MAIN OFFICE FACILITY FOR :

Bank of Roane County
HARRIMAN, TENNESSEE

of $\square$ about c

L.S.

of $\square$ about c

RELEASED FOR CONSTRUCTION

This drawing and the designs thereon are the sole property of Design-Build Concepts, Inc. and its subsidiaries and are to be used for reproduction or use of these documents, in whole or in part, without the written consent of Design-Build Concepts, Inc. specifically authorized by Design-Build Concepts, Inc. in writing, is prohibited.

6-19-88

62-81-9


*design-build
design-build
design-build
design-build*

Concepts

- Consultants
- Designers
- Construction Managers


5187 Roswell Road
Atlanta, Georgia 30342

y0 no 343
 #E68D
 September 9/92 16 RV:
 n2
 signed by 73
 day by 67

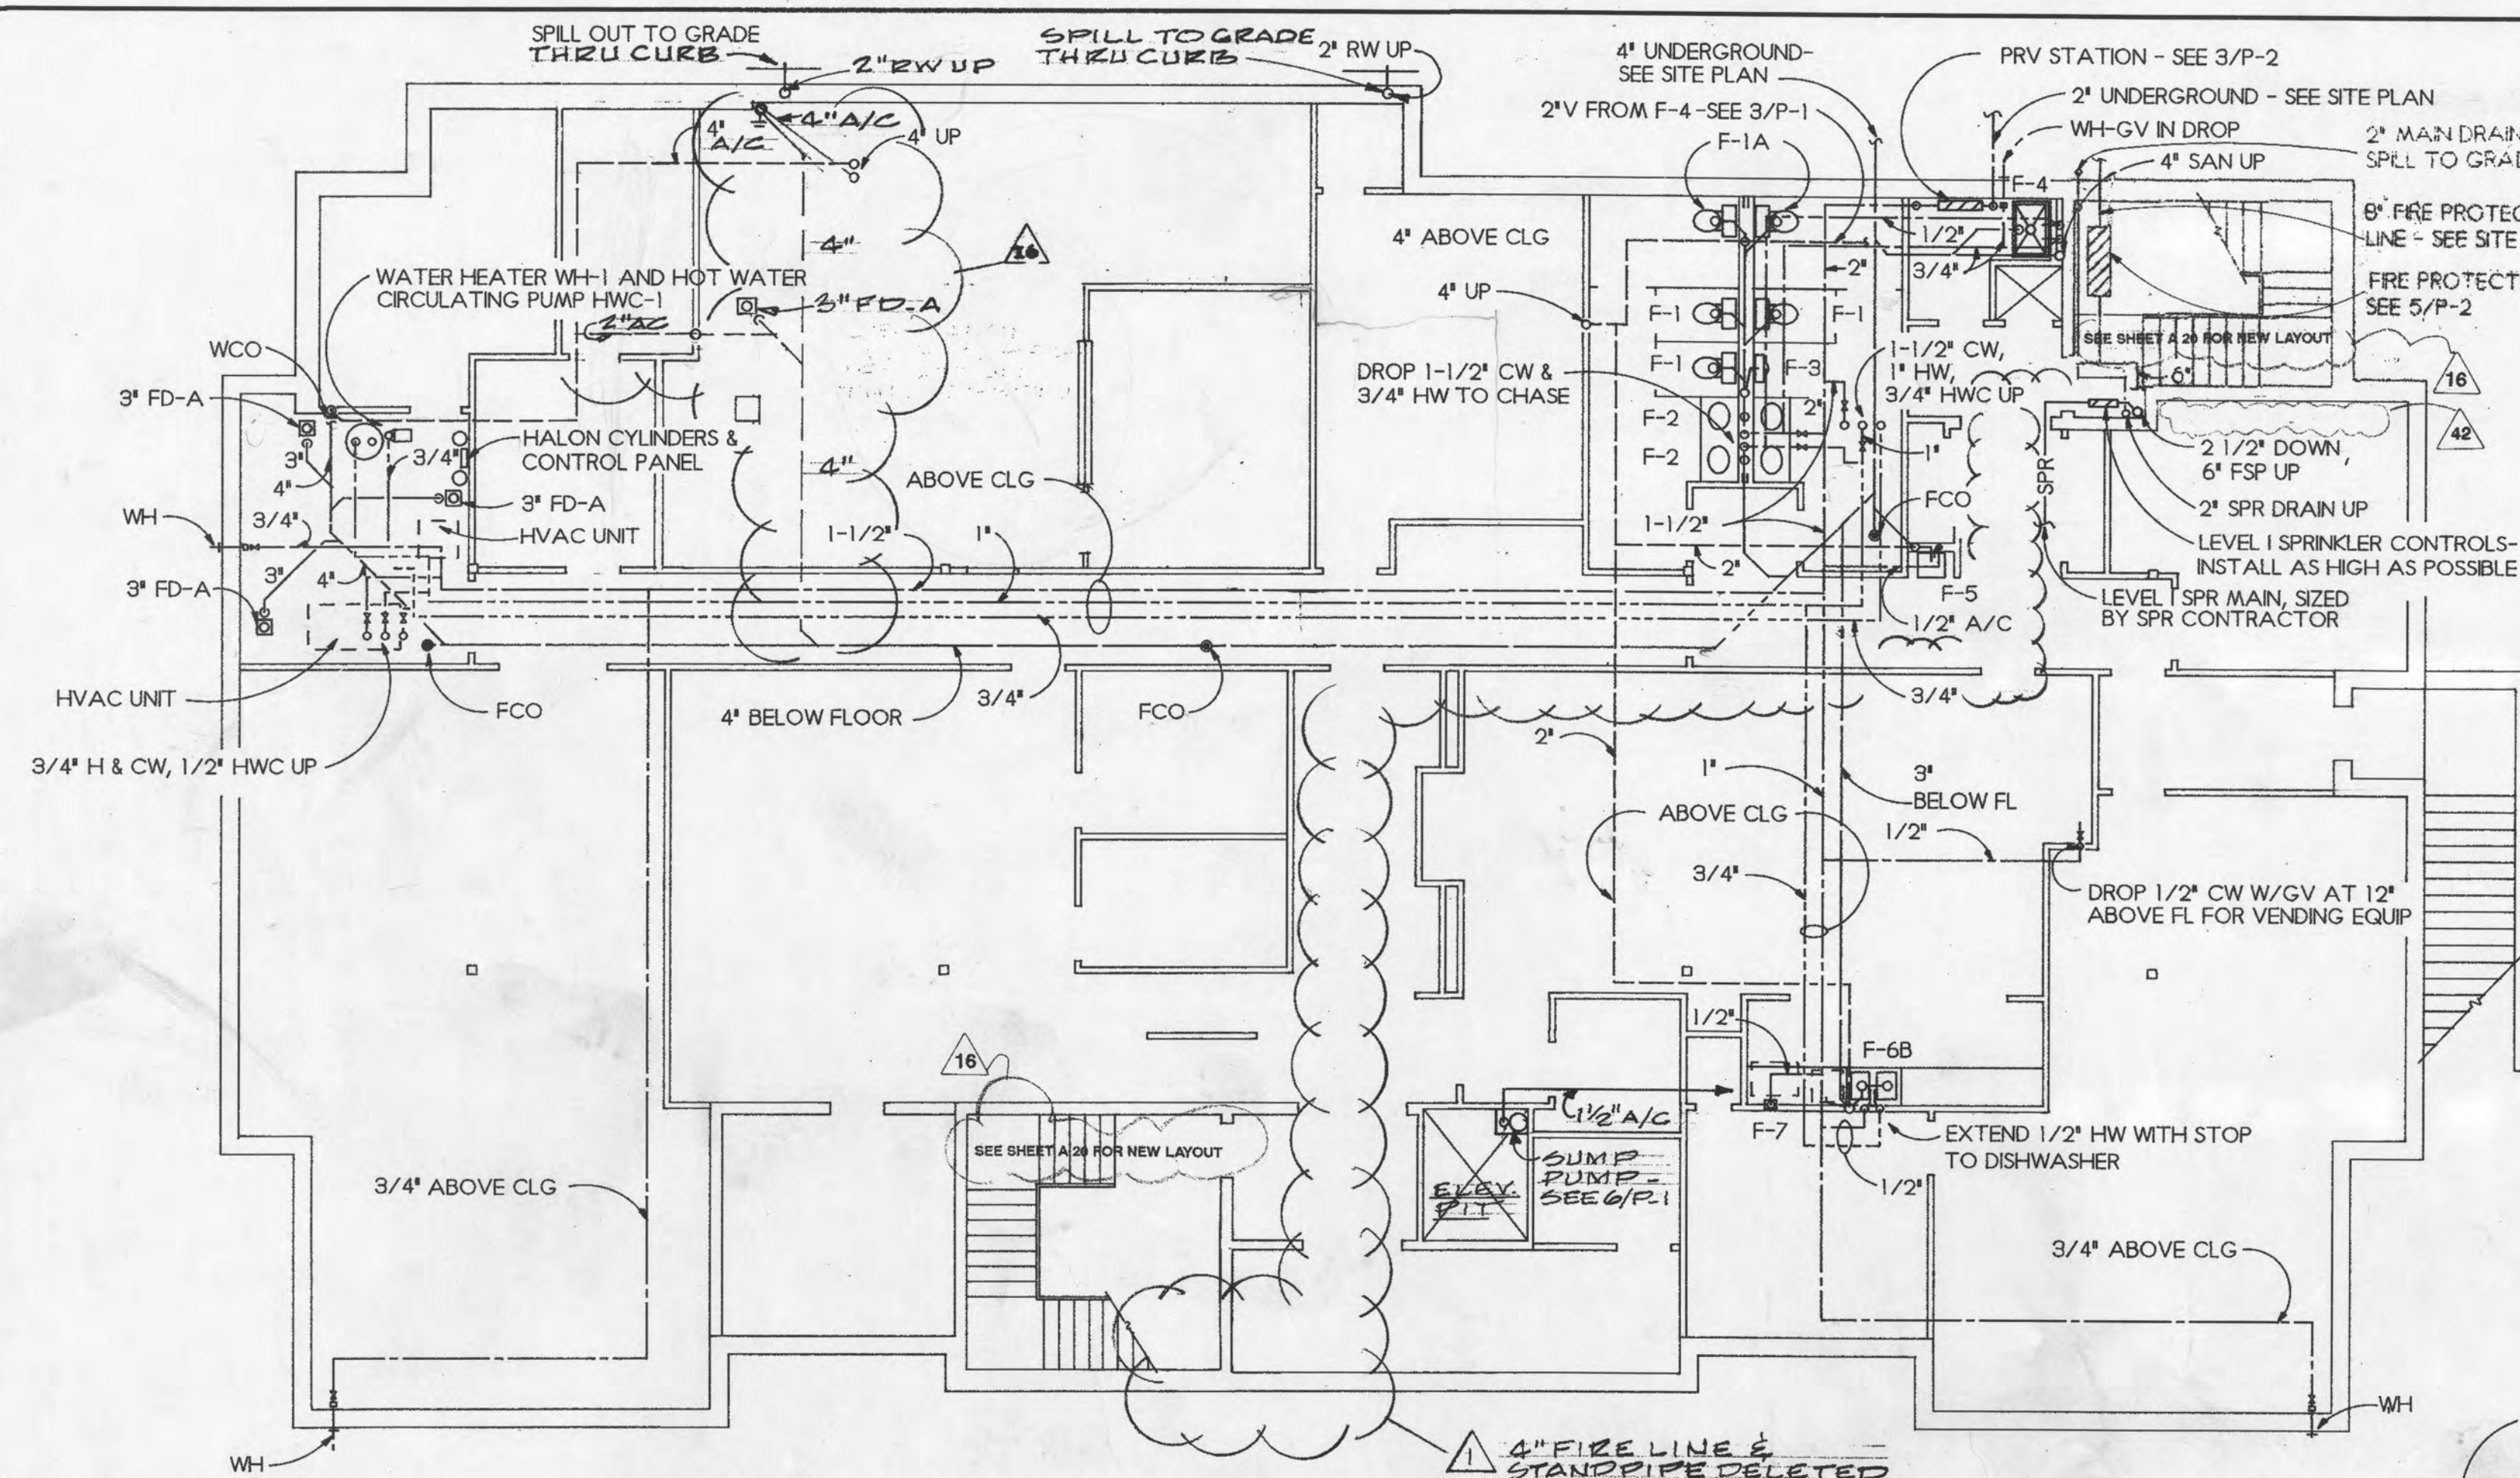

1 PLUMBING PLAN - LEVEL I
P-1 1/8\"=1'-0"


ROOF DRAIN: J. R. SMITH 1630, WITH CAST IRON BODY, FLASHING FLANGE AND 4\" HIGH ROUGH BRONZE TOP.

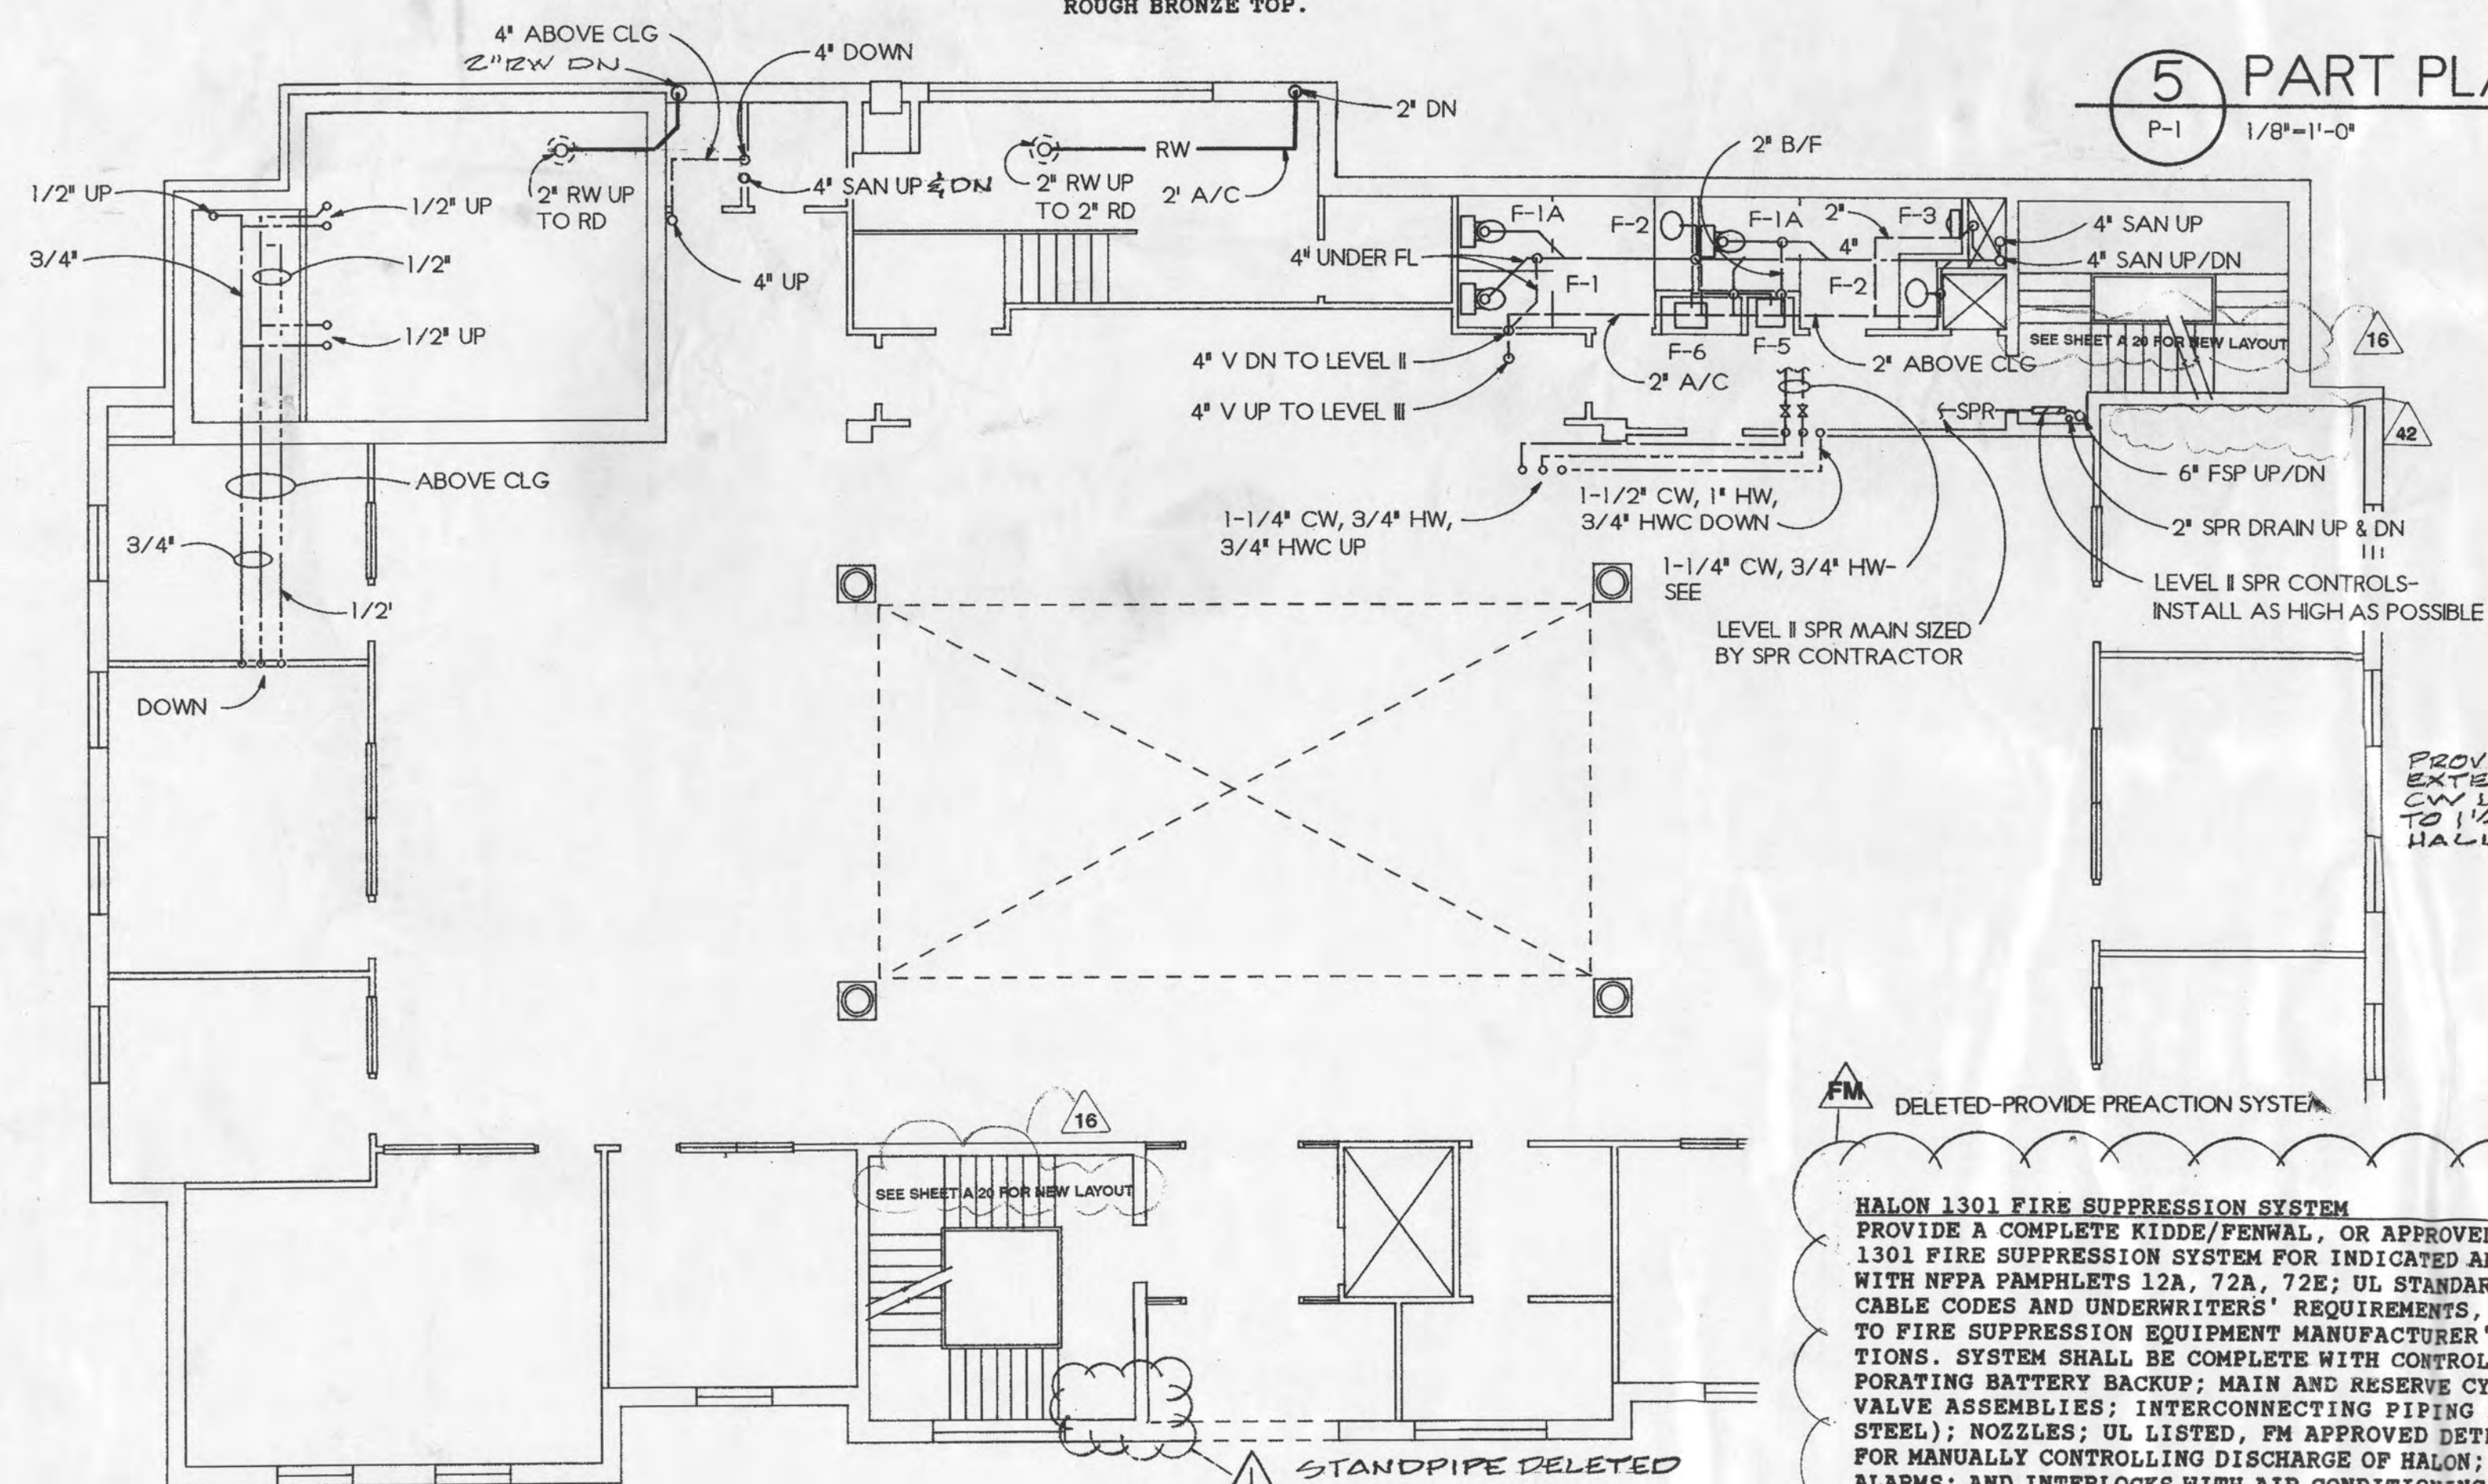

2 PLUMBING PLAN - LEVEL II
P-1 1/8\"=1'-0"


HALON 1301 FIRE SUPPRESSION SYSTEM
PROVIDE A COMPLETE KIDDE/FENVAL, OR APPROVED EQUAL, HALON 1301 FIRE SUPPRESSION SYSTEM FOR INDICATED AREAS, COMPLYING WITH NFPA PAMPHLETS 12A, 72A, 72E; UL STANDARD 1058, APPLICABLE CODES AND UNDERWRITERS' REQUIREMENTS, AND CONFORMING TO FIRE SUPPRESSION EQUIPMENT MANUFACTURER'S RECOMMENDATIONS. SYSTEM SHALL BE COMPLETE WITH CONTROL PANEL, INCORPORATING BATTERY BACKUP; MAIN AND RESERVE CYLINDER(S) AND VALVE ASSEMBLIES; INTERCONNECTING PIPING SYSTEM (BLACK STEEL); NOZZLES; UL LISTED, FM APPROVED DETECTORS; MEANS FOR MANUALLY CONTROLLING DISCHARGE OF HALON; AUDIBLE/VISUAL ALARMS; AND INTERLOCKS WITH AIR CONDITIONING AND FIRE ALARM SYSTEMS. SUBMIT SHOP DRAWINGS FOR ARCHITECT'S APPROVAL. ACCEPTANCE TEST OF THE INSTALLATION SHALL BE PERFORMED IN THE PRESENCE OF THE OWNER'S REPRESENTATIVE.

5 PART PLAN - LEVEL II TOILETS
P-1 1/8\"=1'-0"

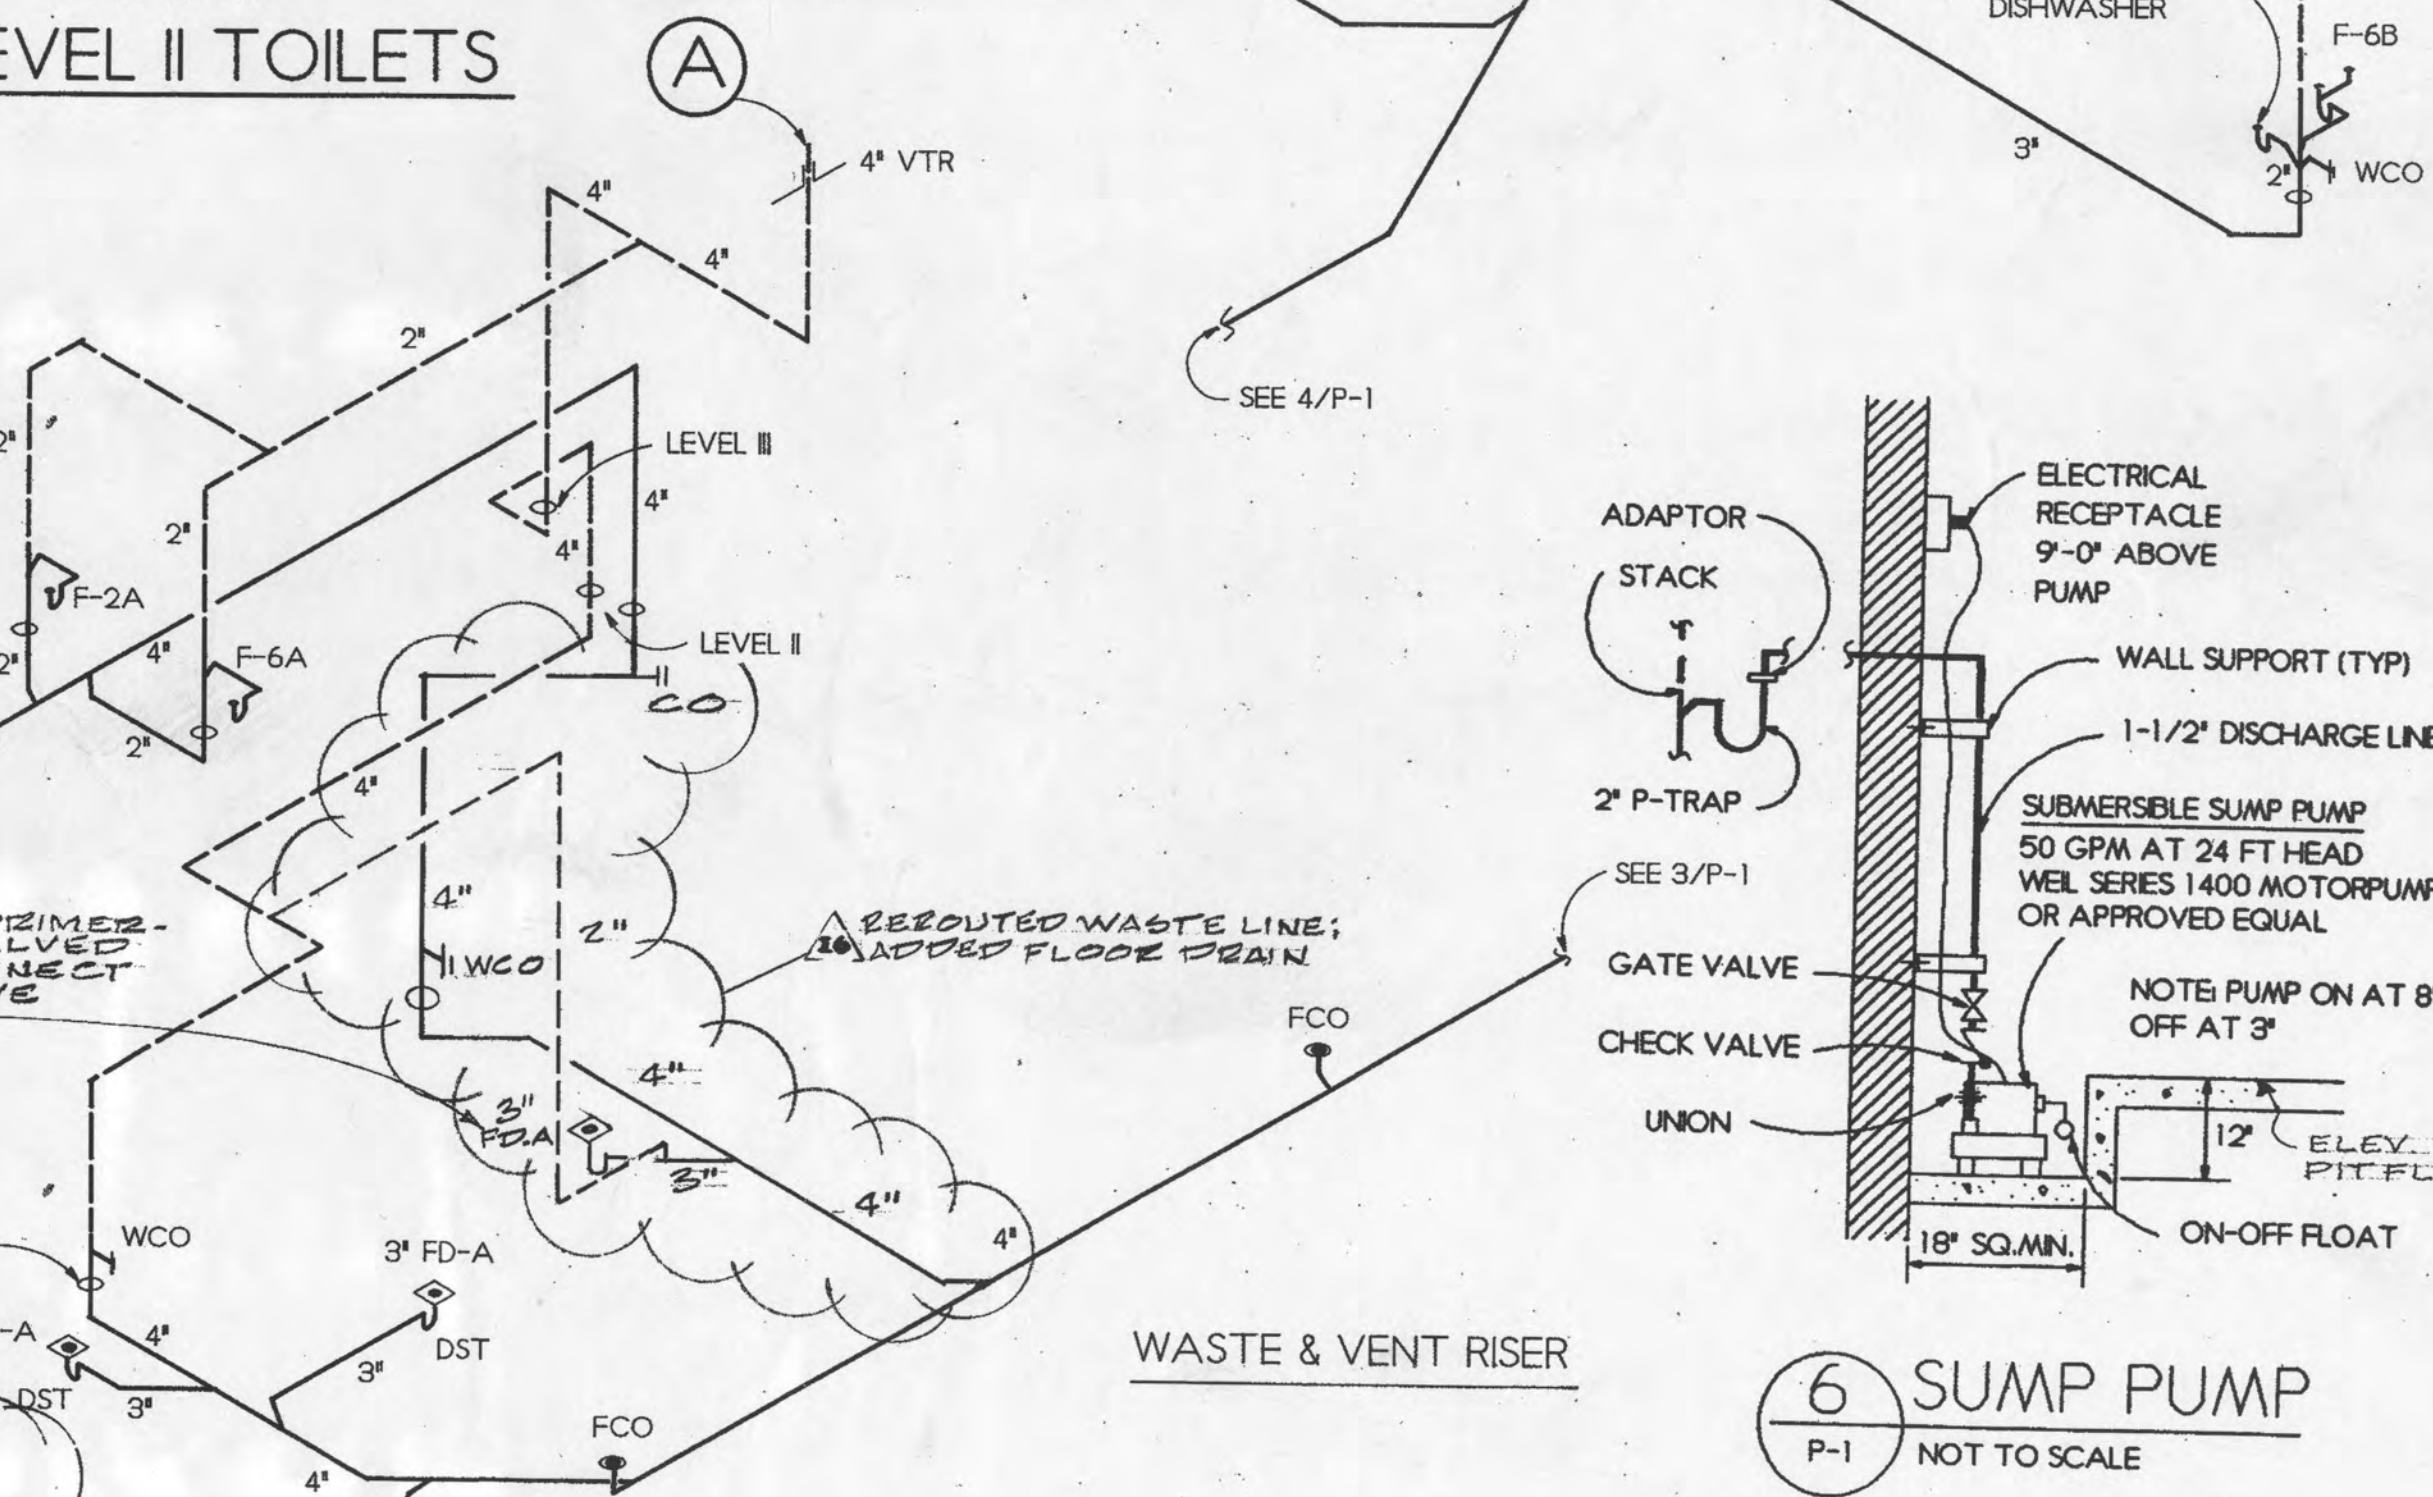


4 RISER DIAGRAM
SCHEMATIC ONLY P-1

NOTE: ALL PIPING INCLUDING UNDERGROUND USED FOR SPRINKLER OR STANDPIPE SYSTEM MUST BE INSTALLED BY A REGISTERED SPRINKLER CONTRACTOR. (RULE 0780-2-7-.08)

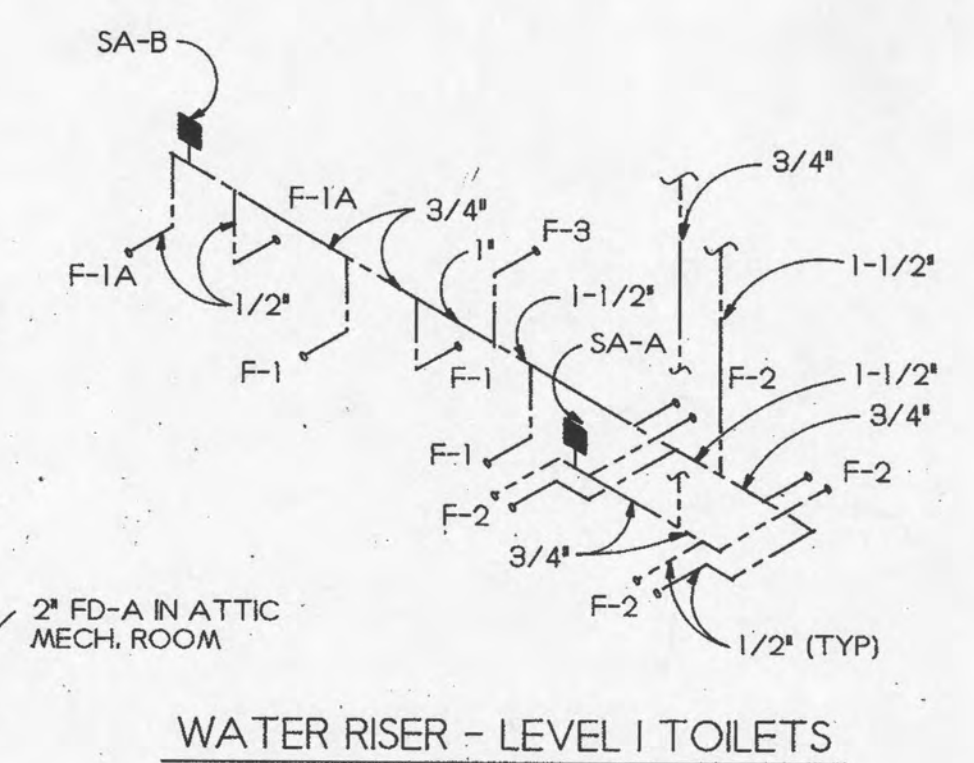

3 RISER DIAGRAM
SCHEMATIC ONLY P-1

NOTE: Hot water and drain piping in H/C toilets to be insulated

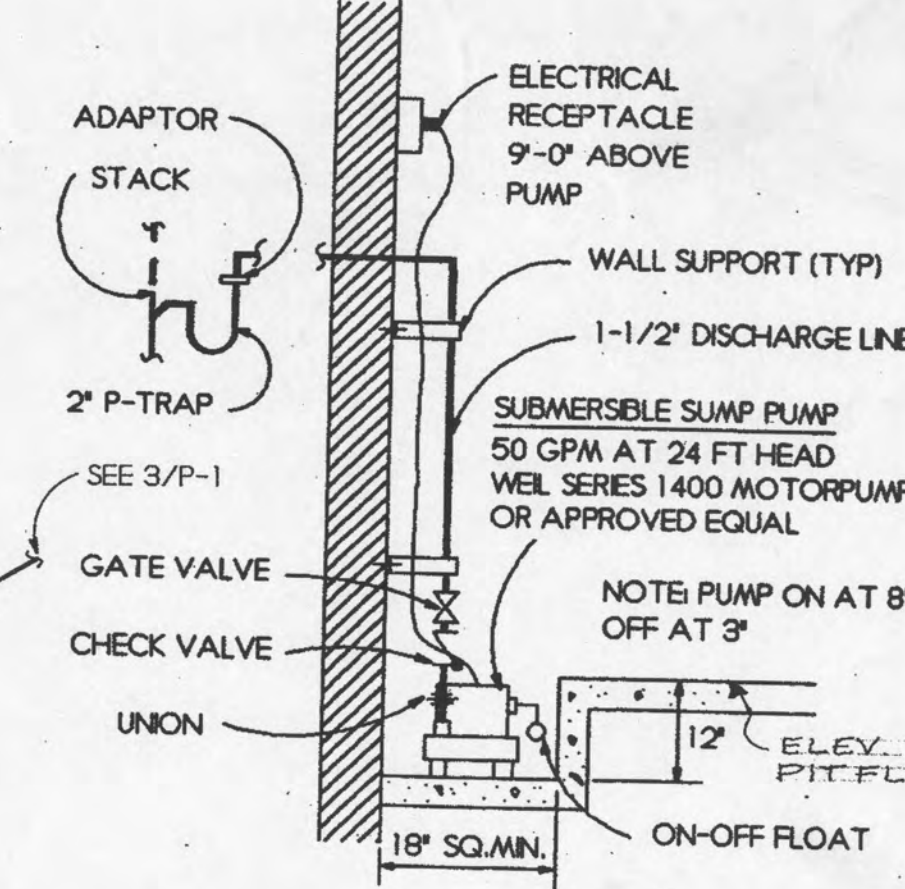

6 SUMP PUMP
P-1 NOT TO SCALE

VAL/TEC ENTERPRISES
125 E. TRINITY PLACE, SUITE 303
DECATUR, GEORGIA 30030
(404) 371-1040



Job No.	343
Revised	
September 1992	15
March 4, 1993	42
RV	
drawn by	RHW
checked by	KFB
date	08/15/93

design-build
design-build
design-build

Concepts

Consultants
Designers
Construction Managers

RELEASED FOR CONSTRUCTION

These drawings are the sole property of Concepts and are to be used only for the project and location specified herein. No part of these drawings may be reproduced, stored in a retrieval system, or transmitted in any form or by any means, electronic, mechanical, photocopying, recording, or by any information storage and retrieval system, without the prior written permission of Concepts.

LEVEL II PLUMBING FLOOR PLANS
& RISER DIAGRAMS


 


NEW MAIN OFFICE FACILITIES FOR:

Bank of Roane County
HARRIMAN, TENNESSEE

JUNE 10, 1992


P-1

of 3 sheets

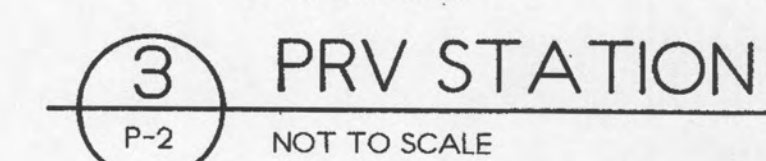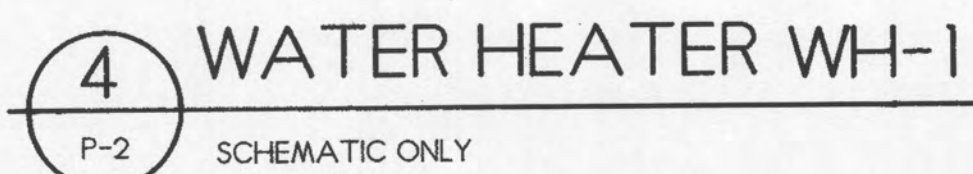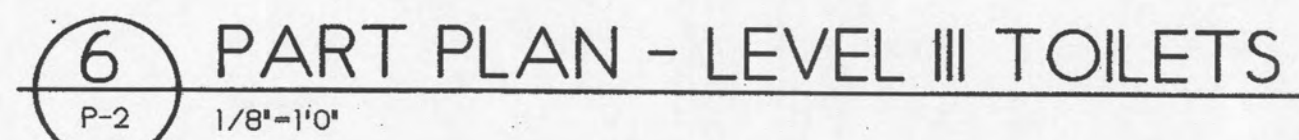

NOTE :
Hot water and drain piping in H/C toilets to be insulated



GEORGIA
 REGISTERED
 No. 5023
 Expires.....
 PROFESSIONAL
 ENGINEER
 RICHARD H. WRIGHT

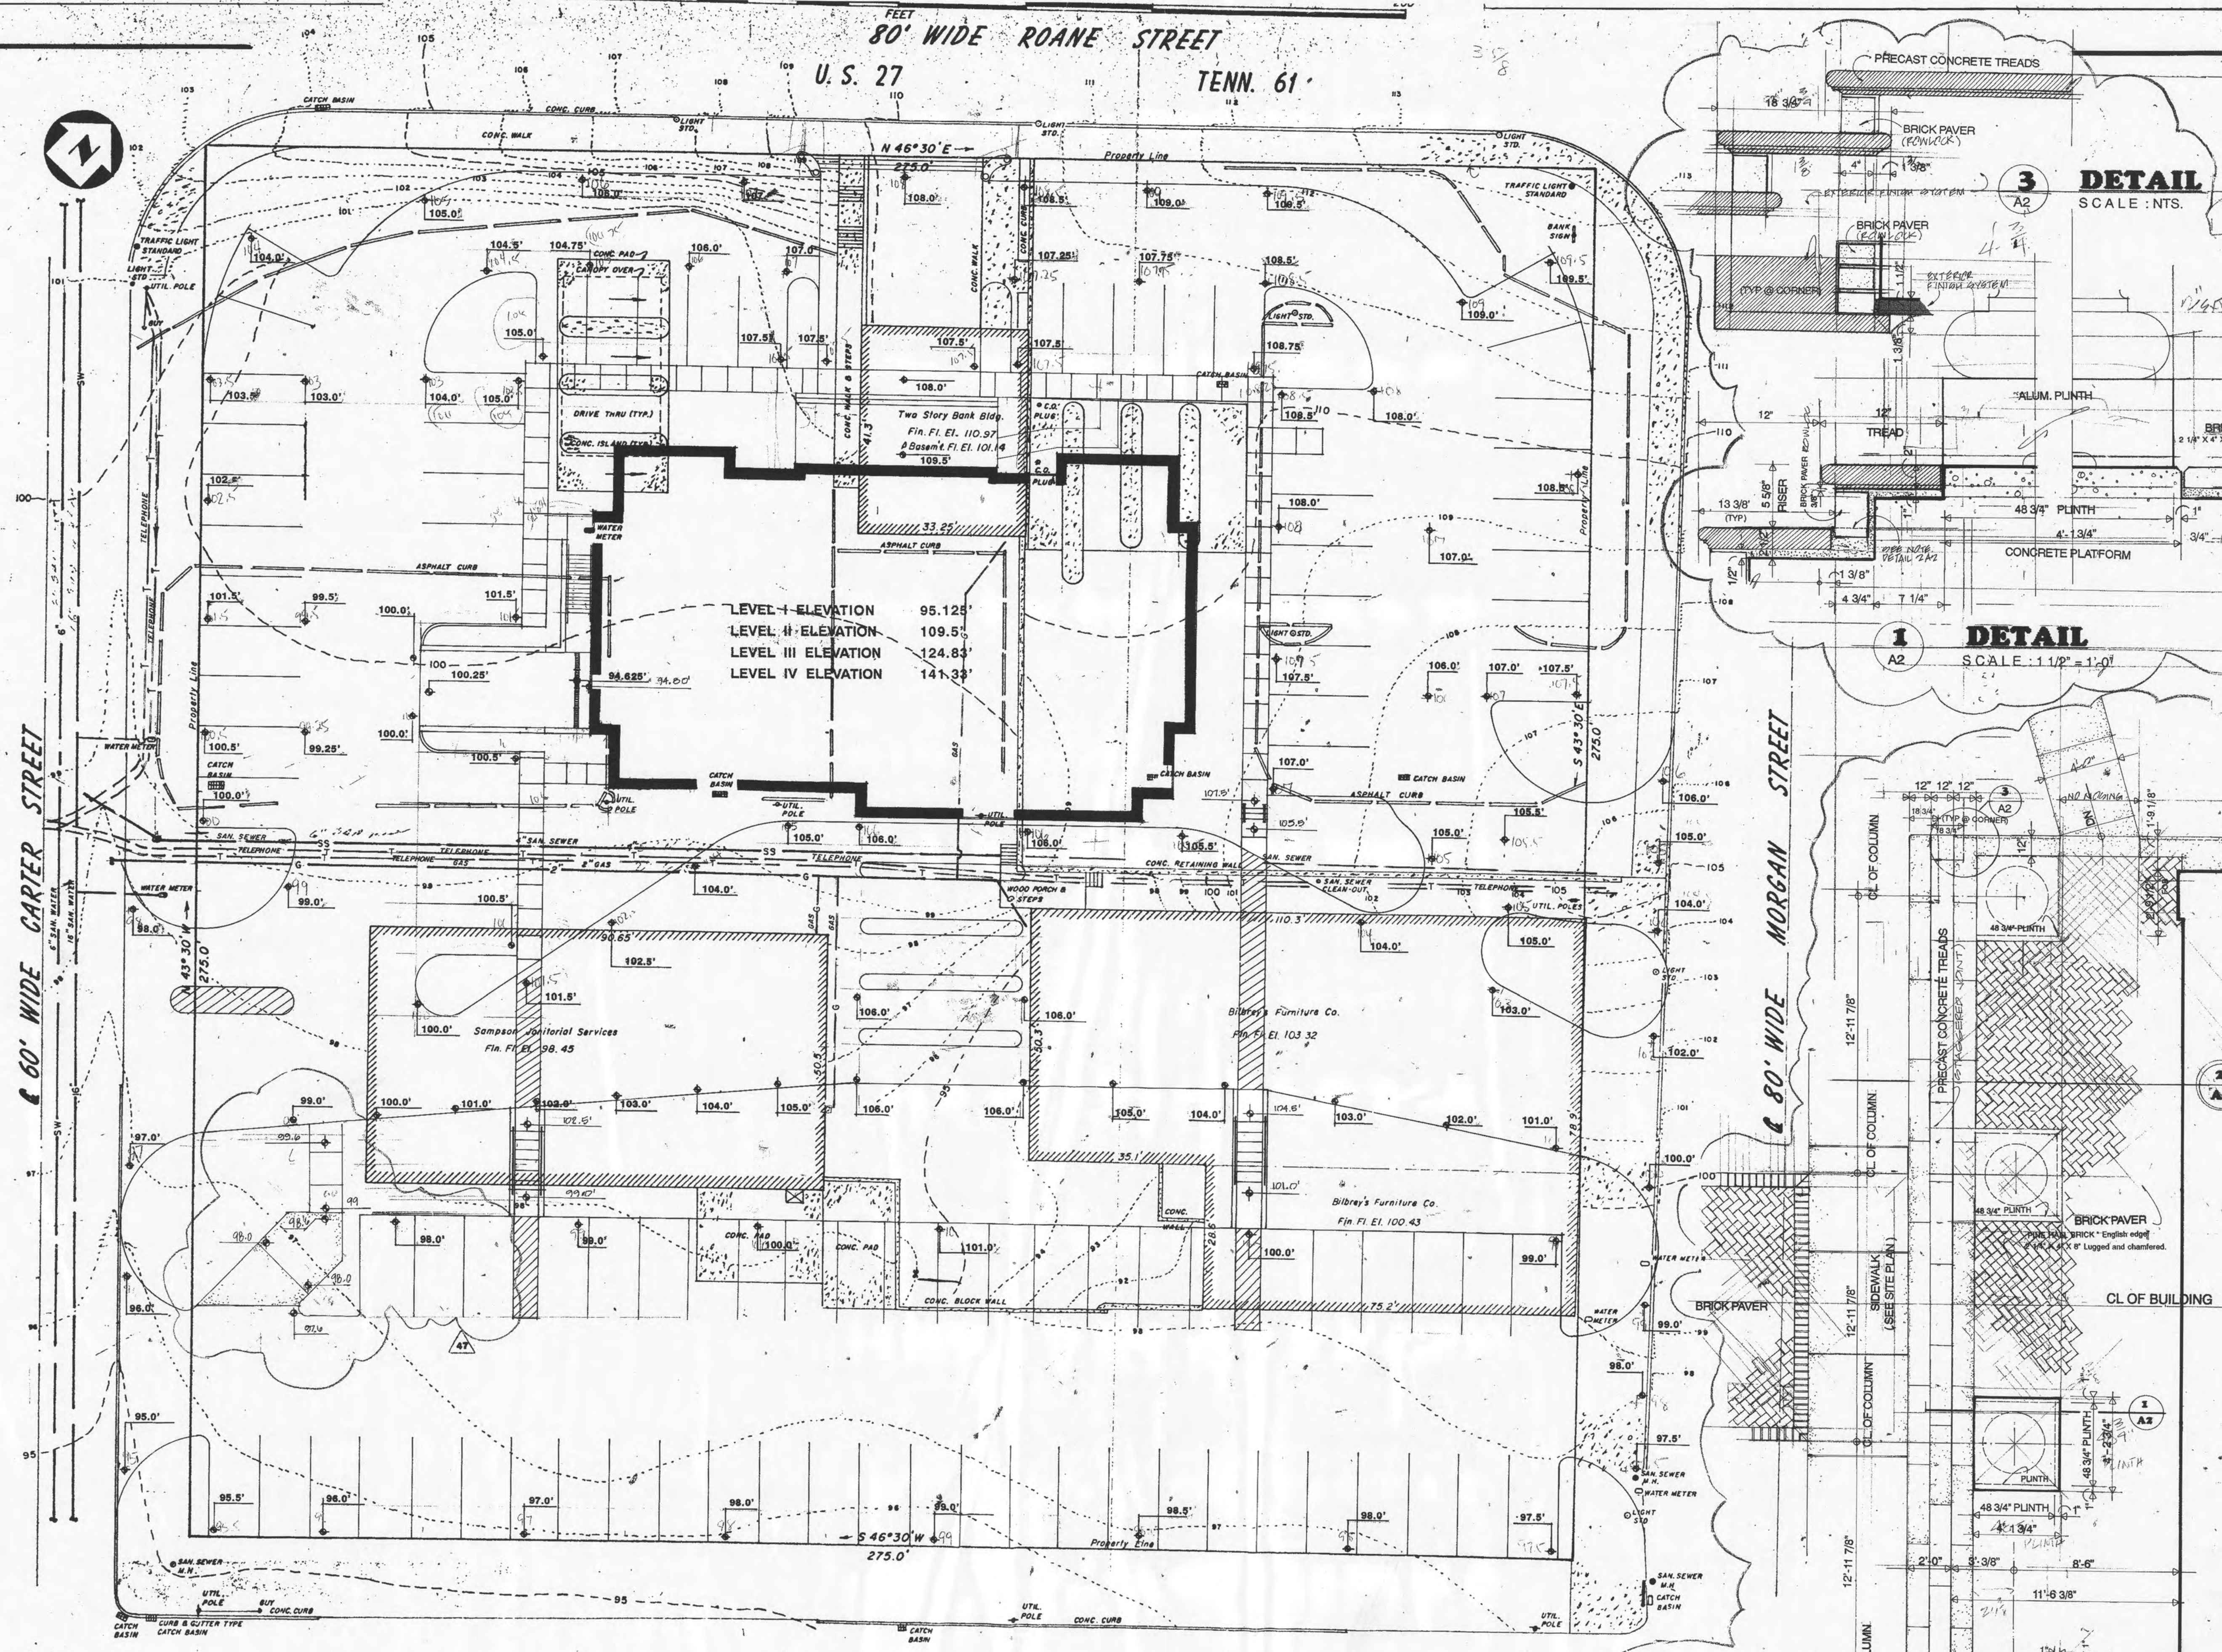

NOTE:
Exact Size, Location, and Elevation of existing utilities are unknown.
Elevations shown are assumed and not above sea level datum.

**BANK OF ROANE COUNTY
HARRIMAN, TENNESSEE**

PLAN
SCALE: 1/16" = 1'-0"

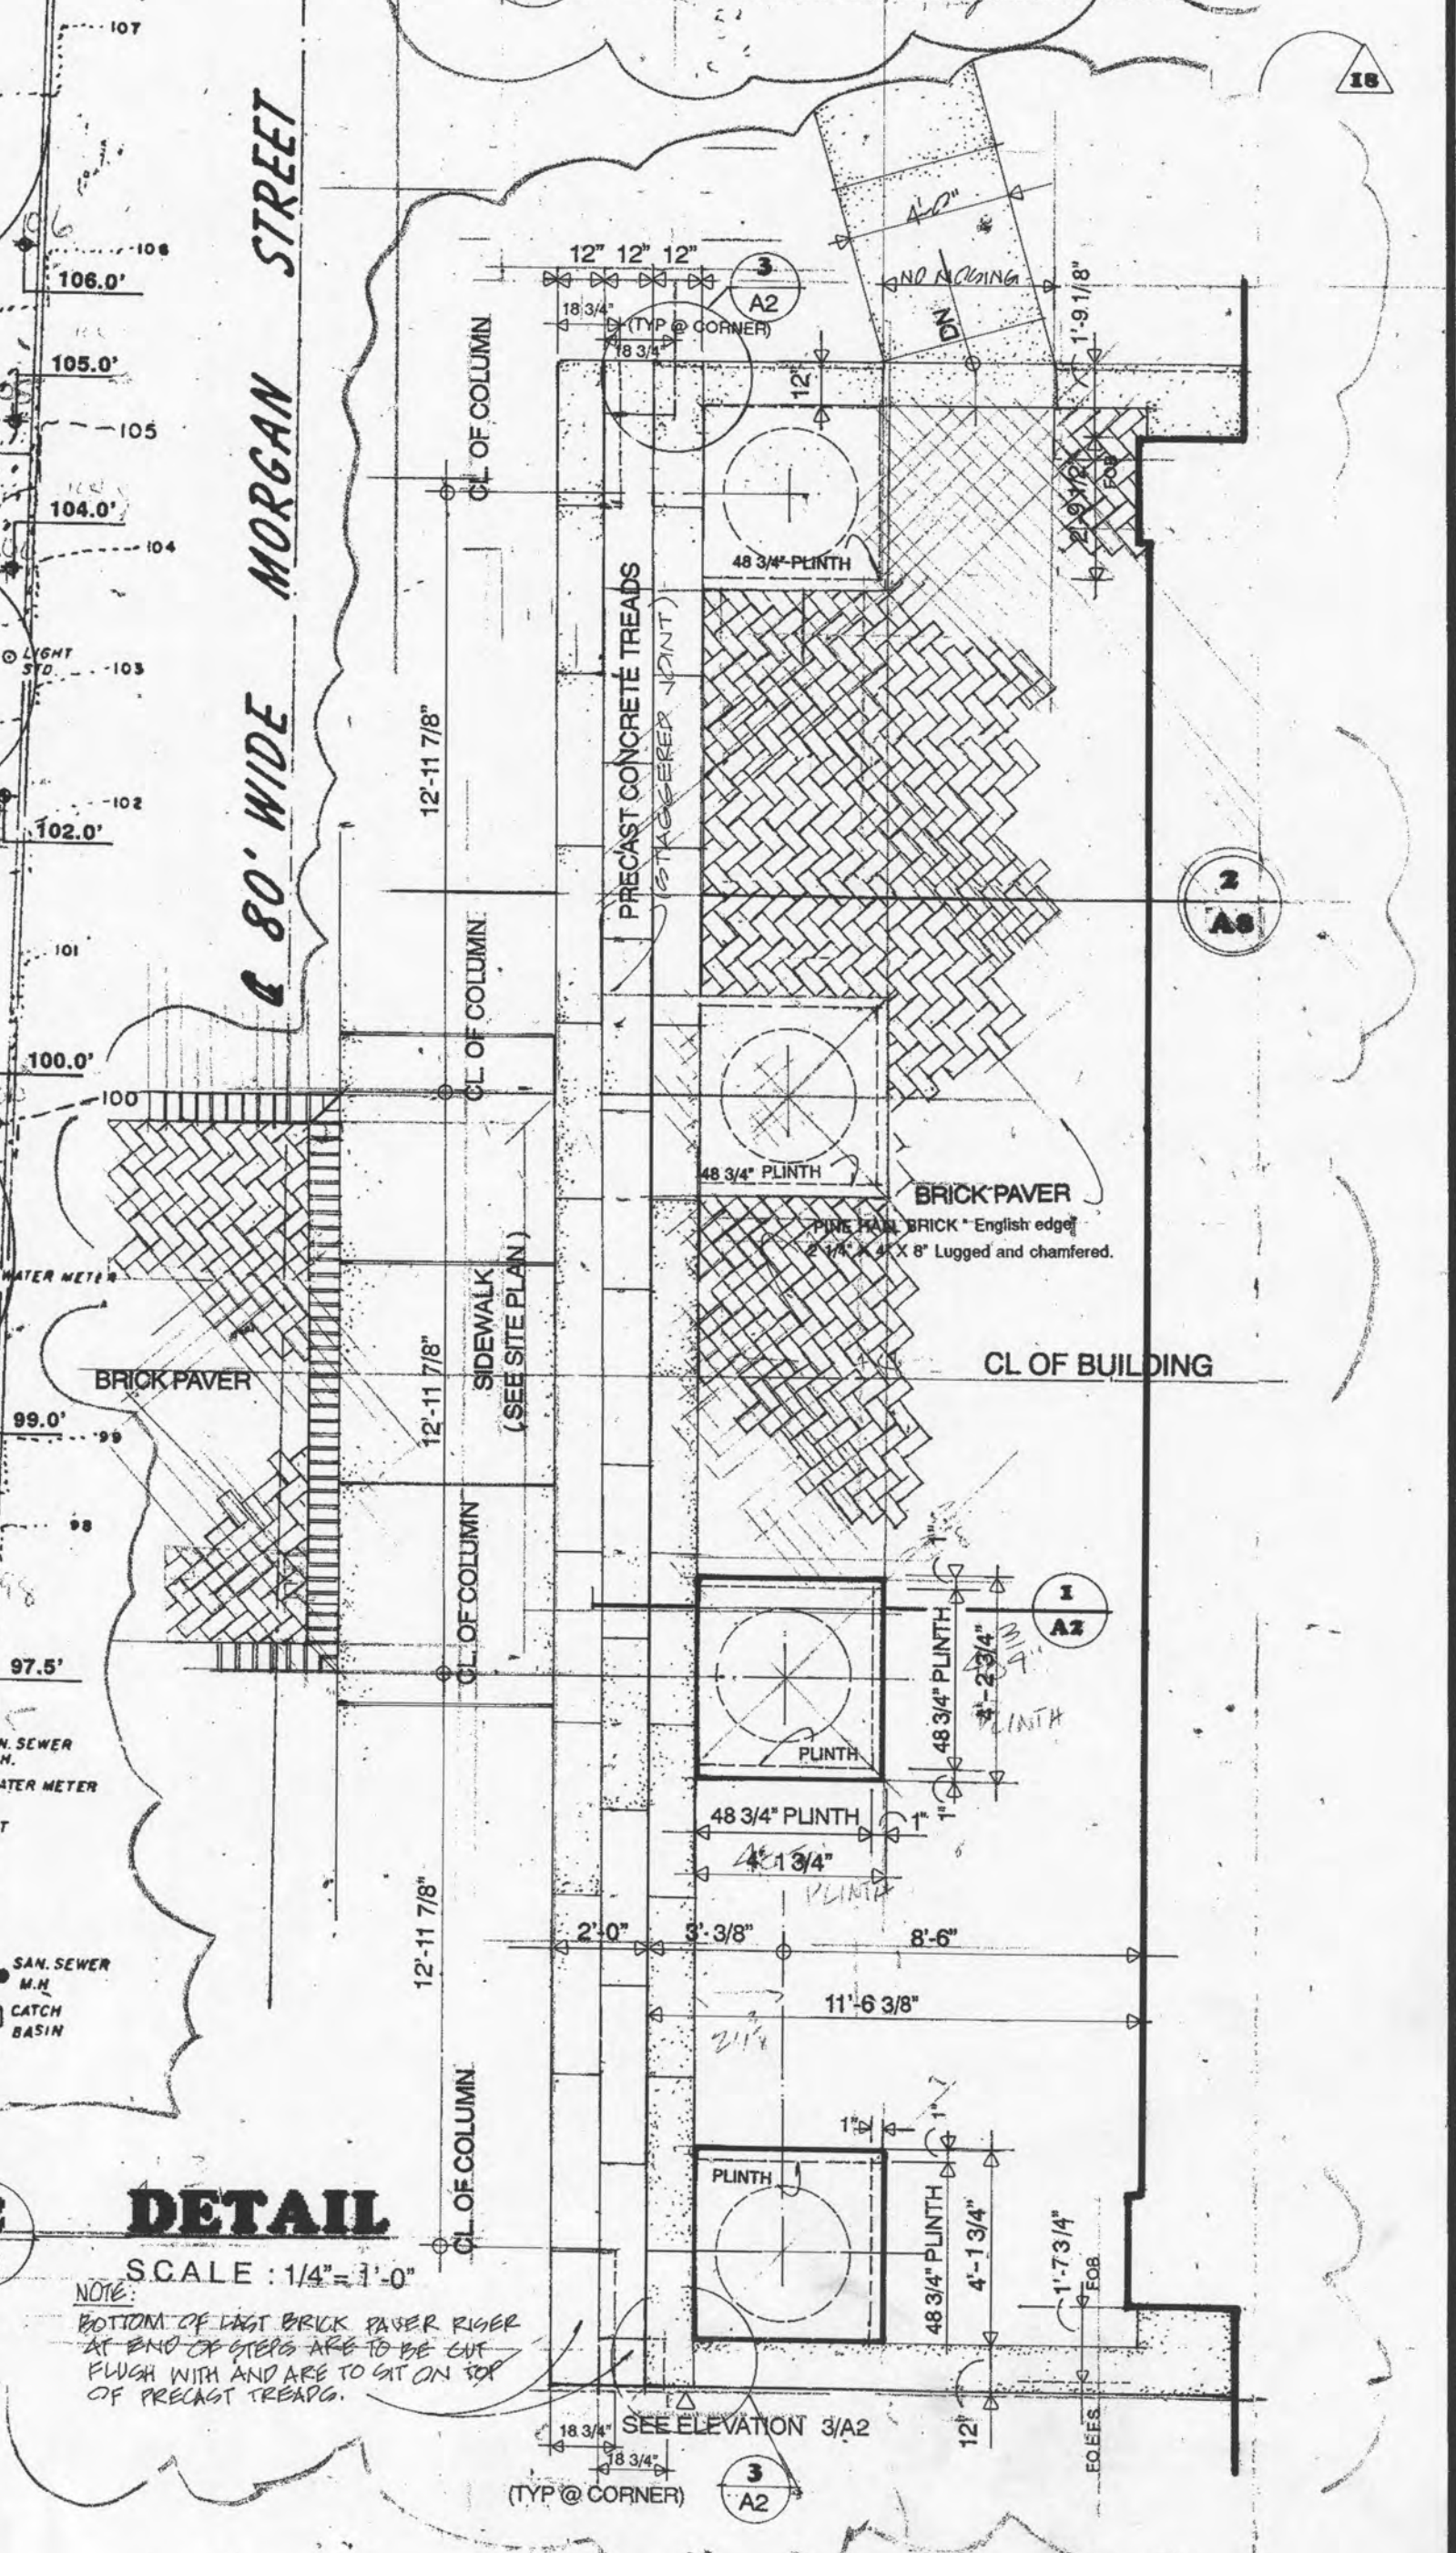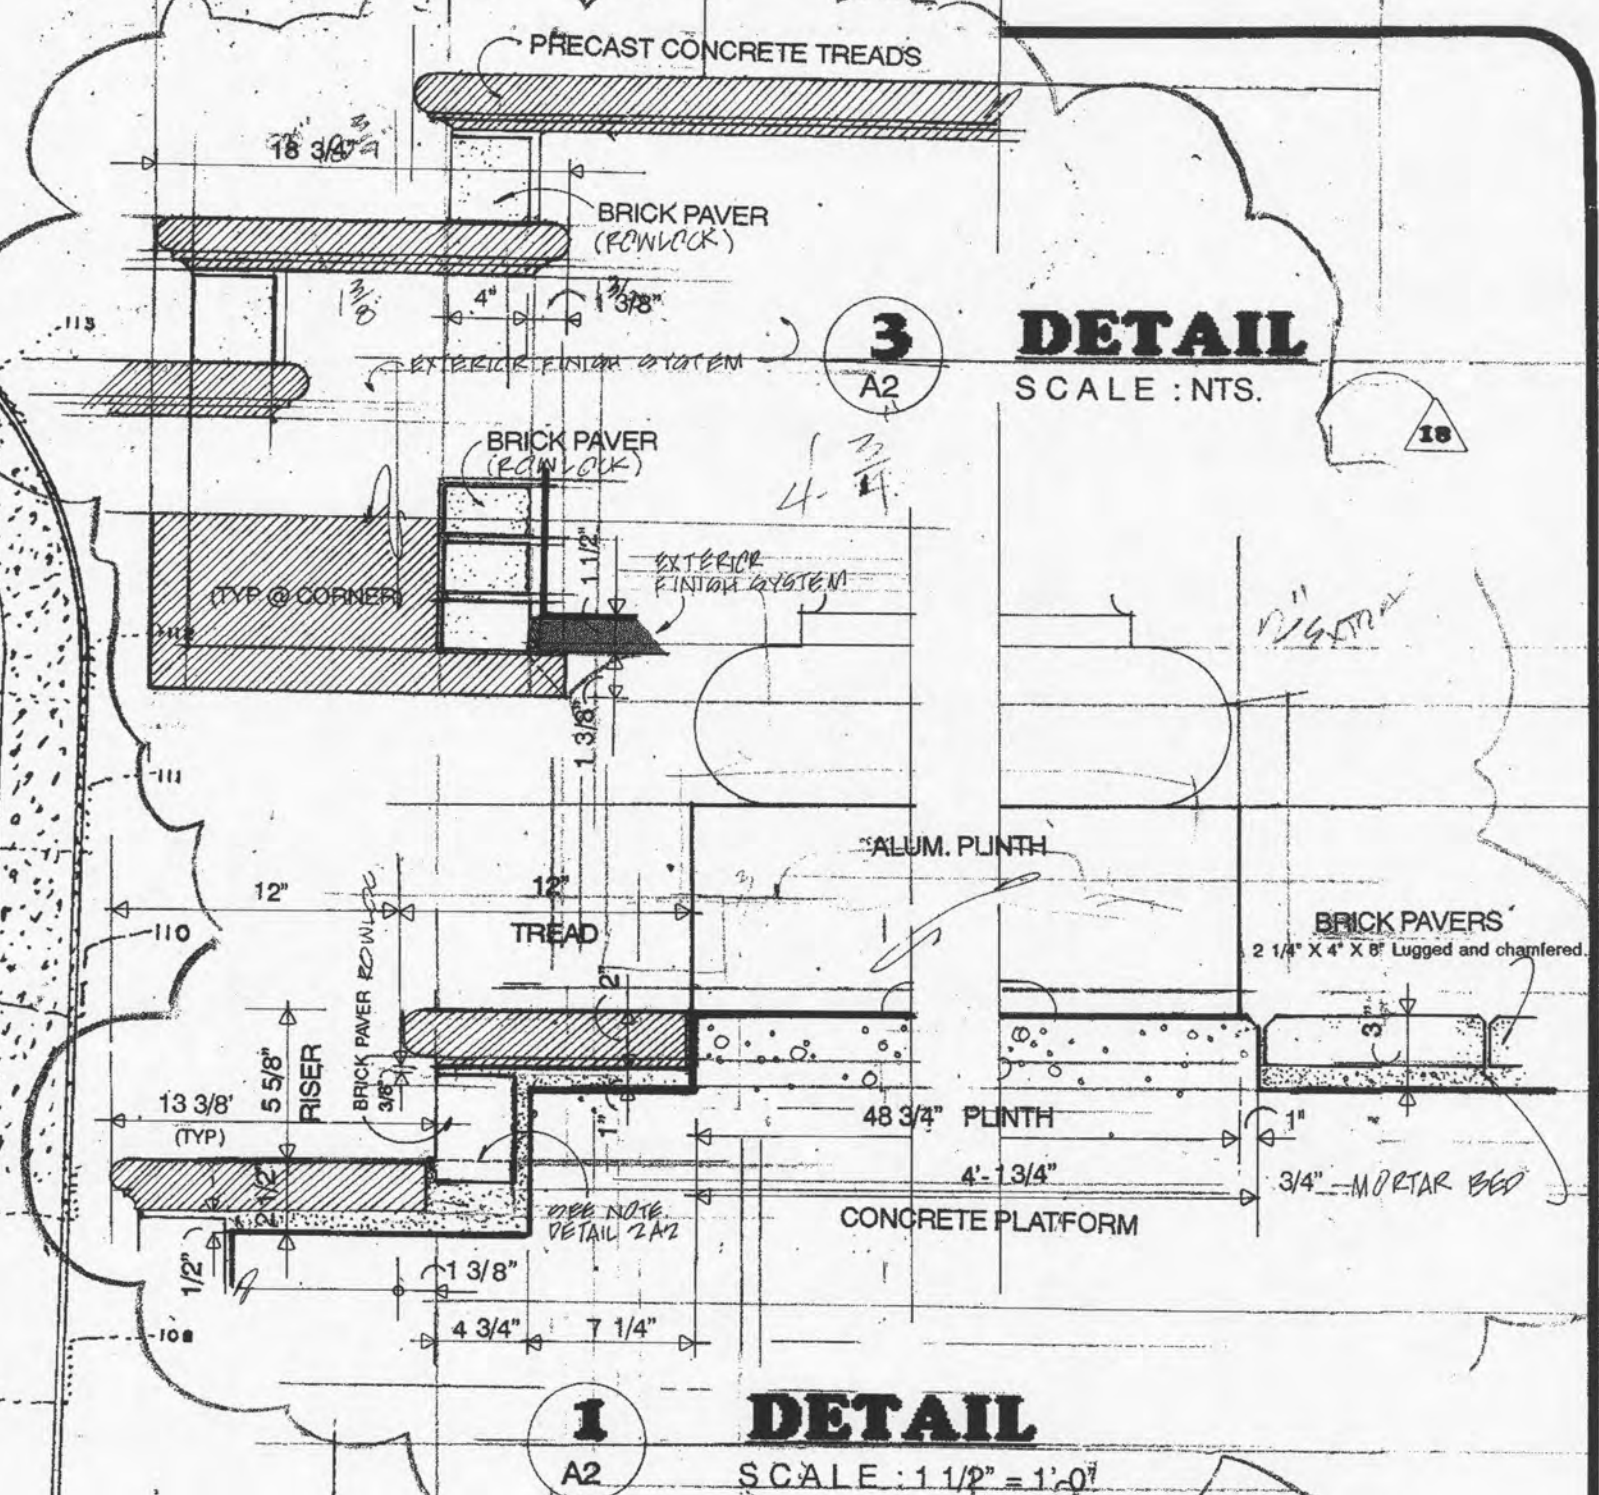

DATE: **JUNE 10, 1992**

SHEET: **A-2**

OF 24 SHEETS

RELEASED FOR CONSTRUCTION

This drawing and the design of the work shown hereon are the sole property of the engineer and shall not be reproduced, copied, or used in any way without the written consent of the engineer.

Robert Smith
Professional Engineer
No. 19913
State of Tennessee

CONSULTANTS

- Designers
- Construction Managers

Concepts
design-build
design-build

1901 255 0550
550 Russell Road
Reno, Georgia 30422

SITE GRADING & DRAINAGE


A NEW MAIN OFFICE FACILITY FOR:

Bank of Roane County
HARRIMAN, TENNESSEE

DATE: **JUNE 10, 1992**


SHEET: **A-2**

OF 24 SHEETS


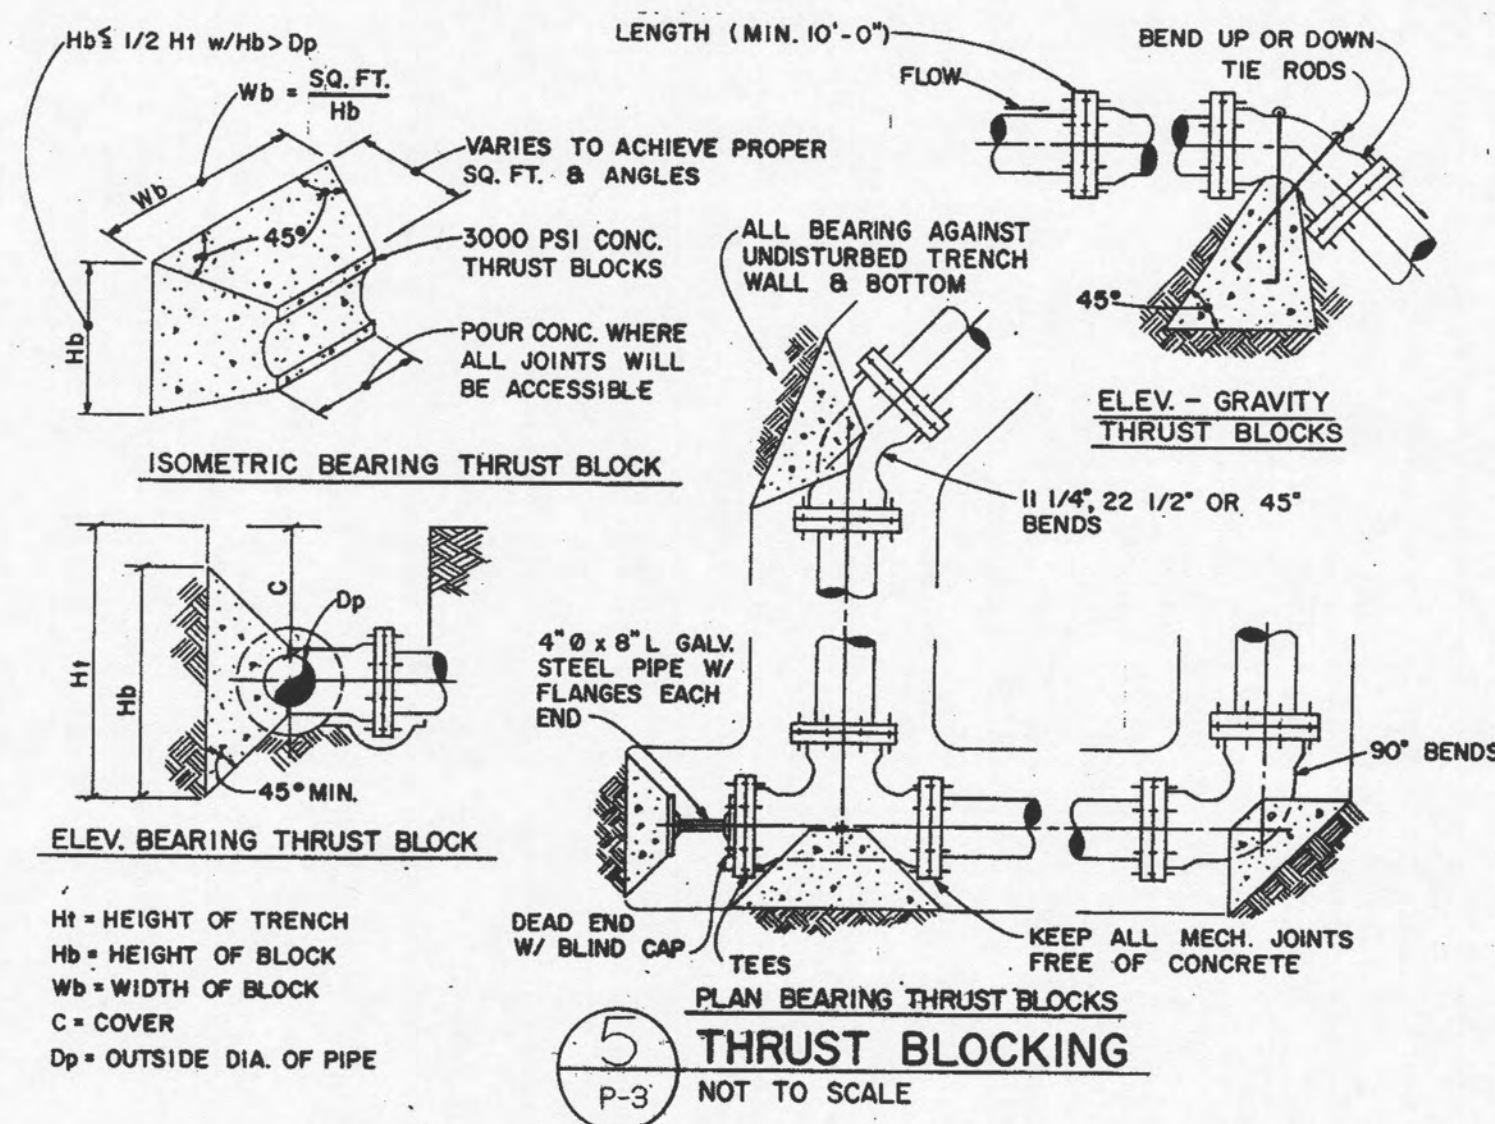


THRUST BLOCKING SCHEDULE									
BEARING THRUST BLOCKS					GRAVITY THRUST BLOCKS				
AREA OF BEARING FACE (Hb x Wb) Numbers are in (SQ. FT.)					VOLUME OF CONCRETE Numbers are in (CU. FT.)				
PIPE DIAMETER (Dp)	90° BEND	45° BEND	22 1/2° BEND	11 1/4° BEND	TEES	90° BEND	45° BEND	22 1/2° BEND	11 1/4° BEND
4"	2	2	1.5	1.5	2	2	2	1.5	1.5
6"	5	3	2	2	4	4	3	2	2
8"	8	5	3	3	6	6	4	3	3
10"	13	7	4	4	9	9	6	4	4
12"	18	10	6	6	13	13	9	6	6


THIS SCHEDULE IS BASED ON:
 • LINE PRESSURE OF 225 PSI (OPERATING PLUS SURGE PRESSURES)
 • BEARING WALL OF 2000 PSI (SAND & GRAVEL CEMENTED WITH CLAY)
 • FOR DIFFERENT SOILS ENCOUNTERED ON PROJECT, CONTRACTOR IS TO MULTIPLY AREA BY THE FOLLOWING FACTORS: SOFT CLAY x4, SAND x2, SAND & GRAVEL x1.25, AND SHALE x4.
 • MUCK OR PEAT SOILS CANNOT BE DEPENDED ON TO RESIST THRUST AND JOINTS MUST BE RODDED ONLY.

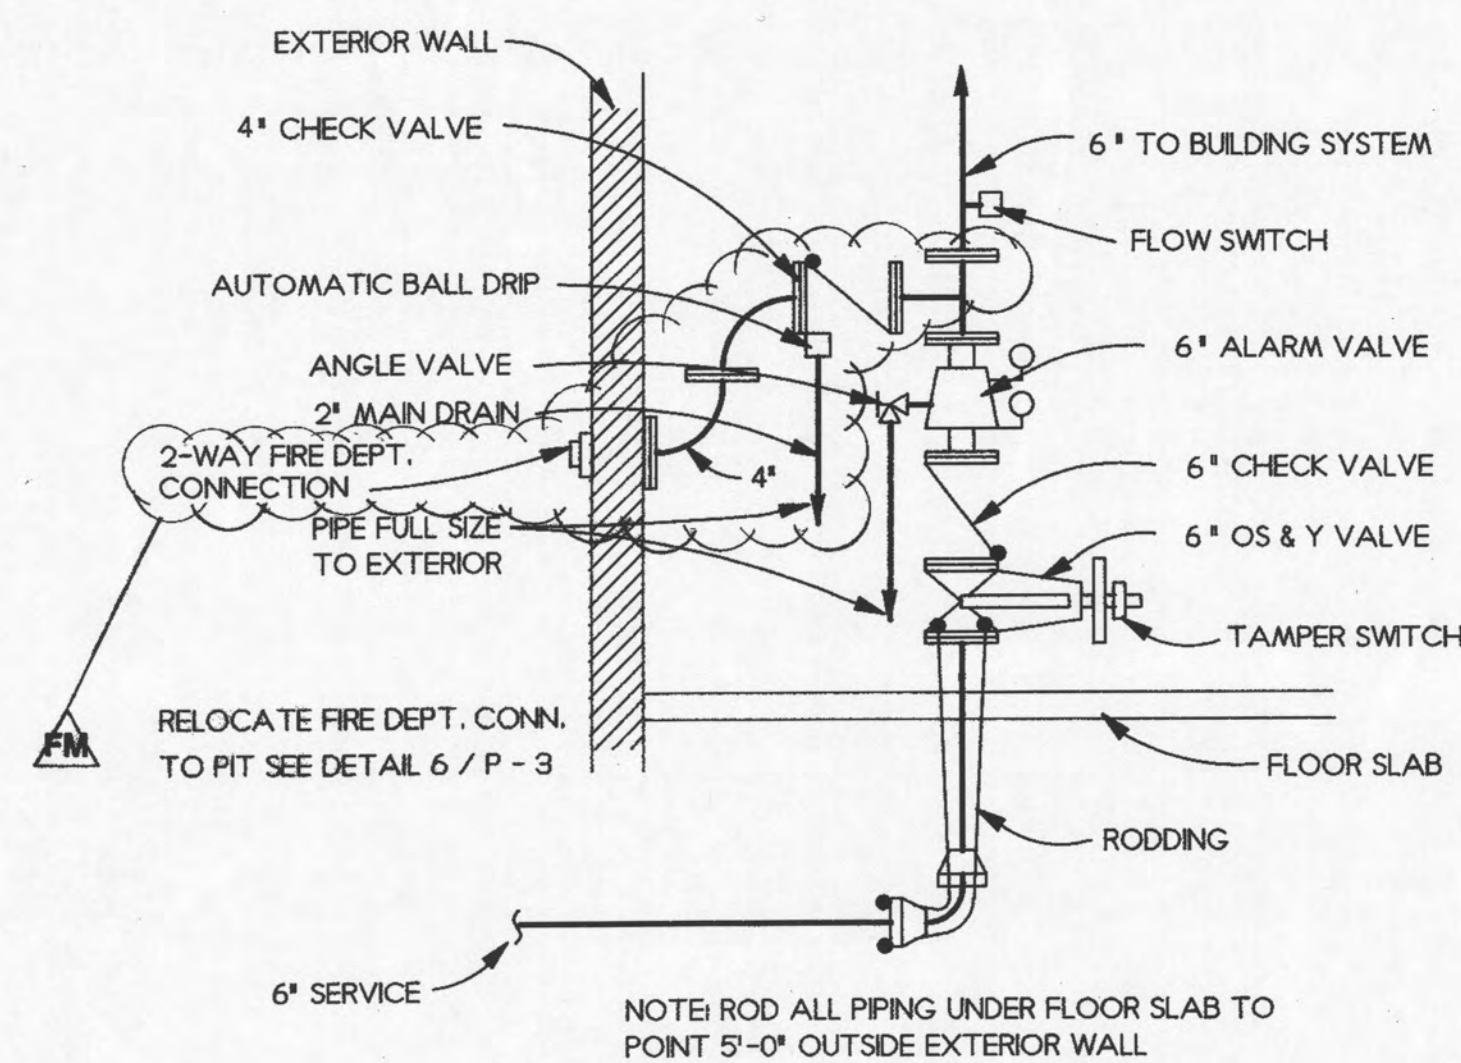


2 FIRE PROTECTION SERVICE
 P-3 NOT TO SCALE
 NOTE: THIS DETAIL SUPERSEDES DETAIL 5/P-2.

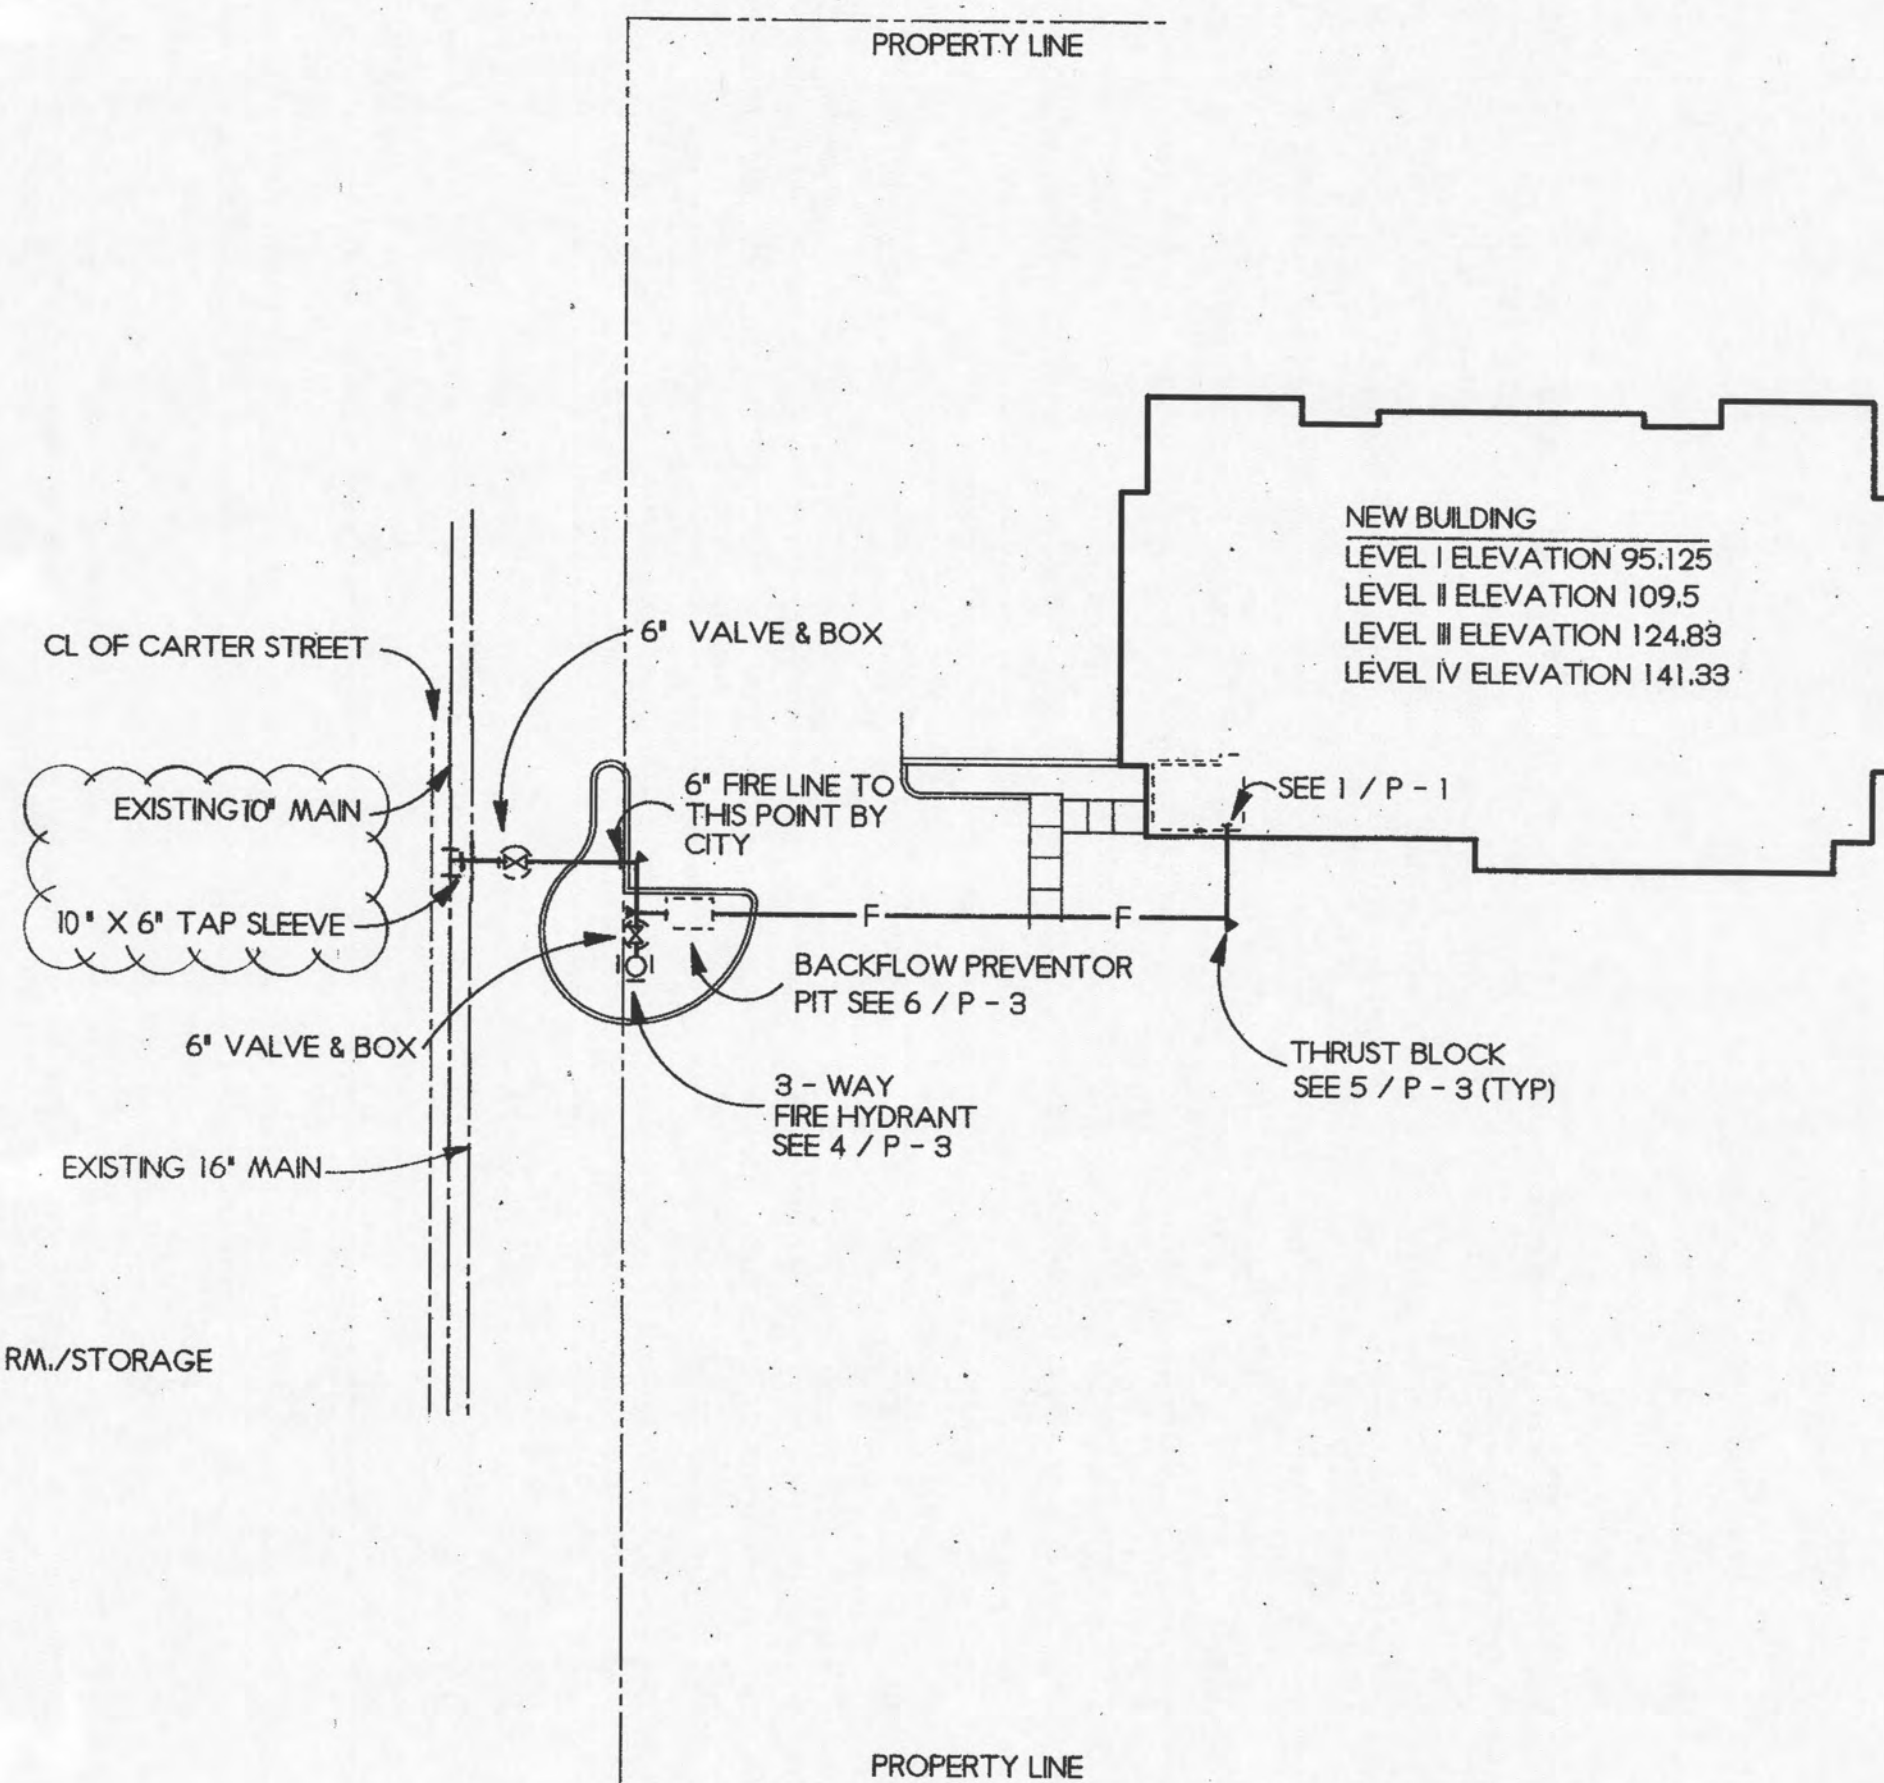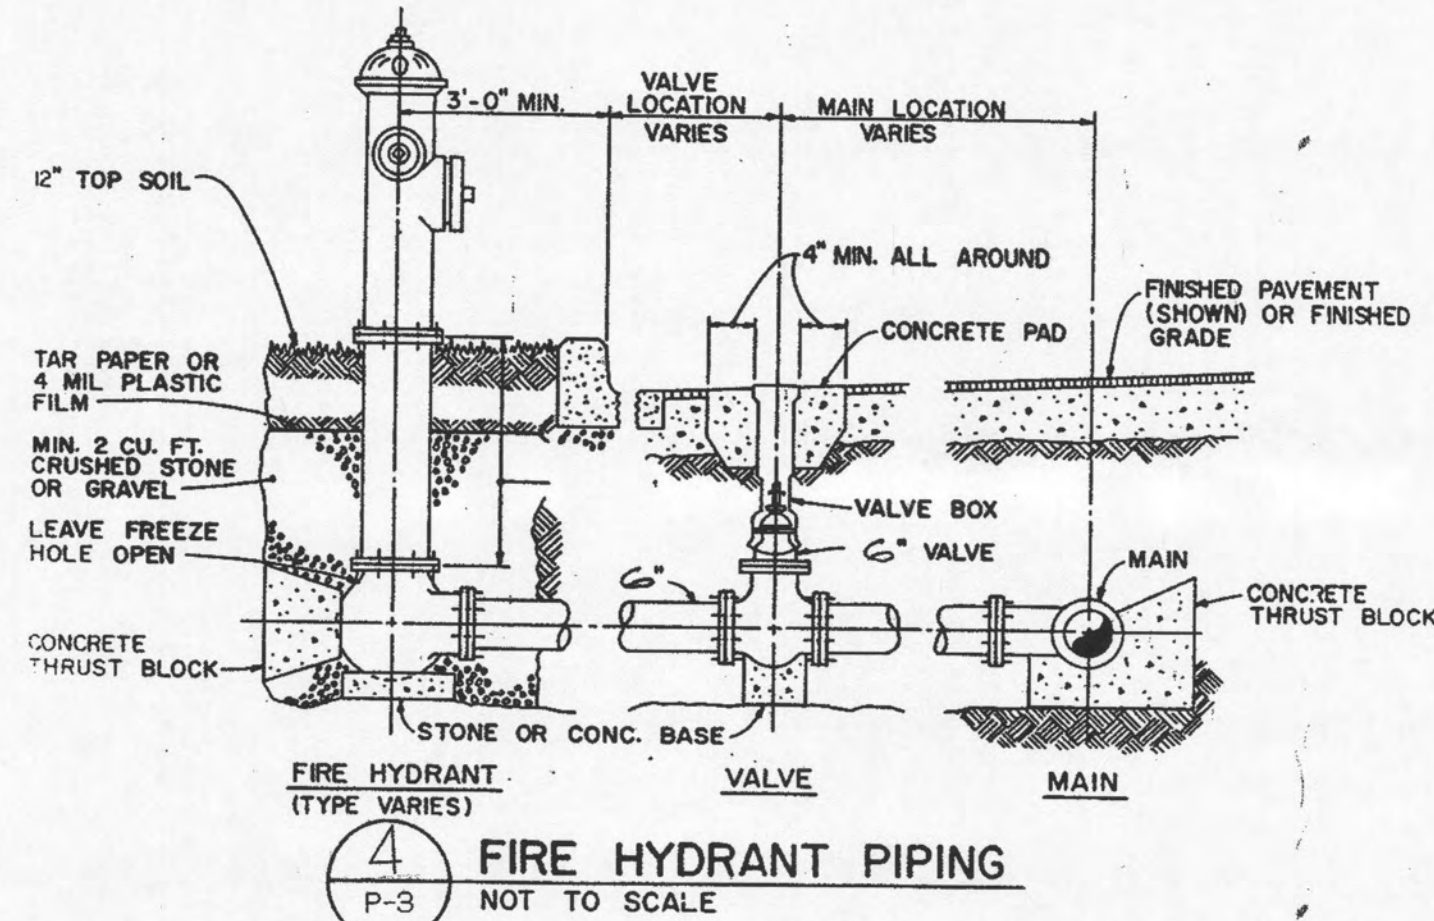

- NOTES**
1. FLOW/PRESSURE TEST DATA FOR EXISTING FIRE HYDRANTS RECORDED BY RUSSELL MILLER, CITY OF HARRIMAN, 1030 AM, AUGUST 13, 1992.
 2. MAINTAIN A MINIMUM OF 3'-0" COVER OVER THE NEW FIRE SUPPLY PIPING.
 3. INFORMATION ON EXISTING MAINS AND HYDRANTS TAKEN FROM SURVEYS BY FRED MOORE, REGISTERED LAND SURVEYOR (TENN. NO. 21)

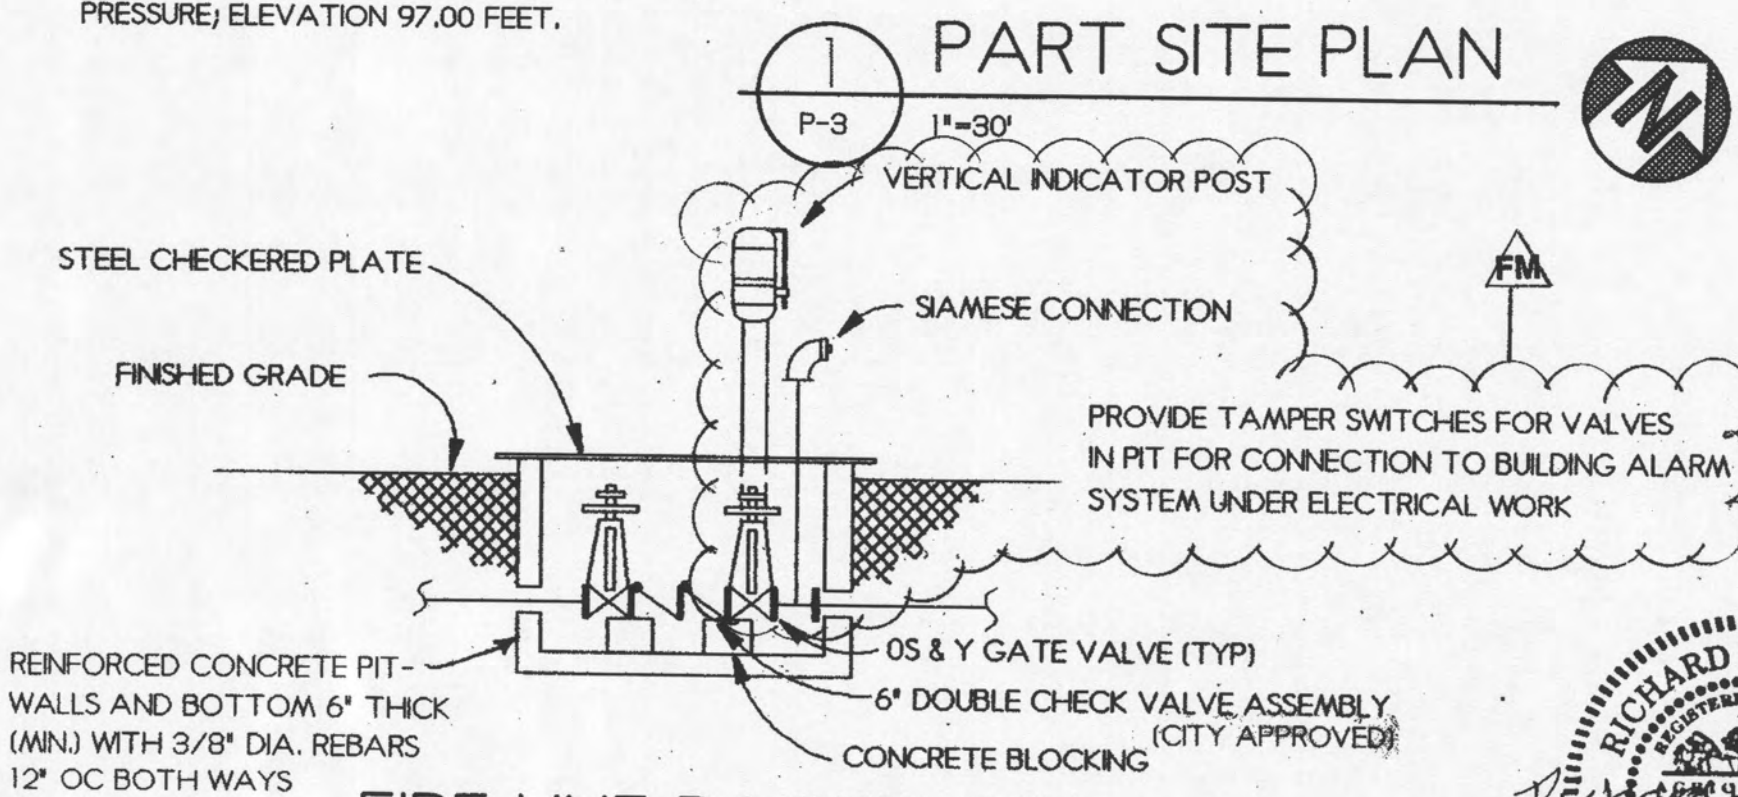


3 FIRE PROTECTION SCHEMATIC
 P-3 DIAGRAMMATIC

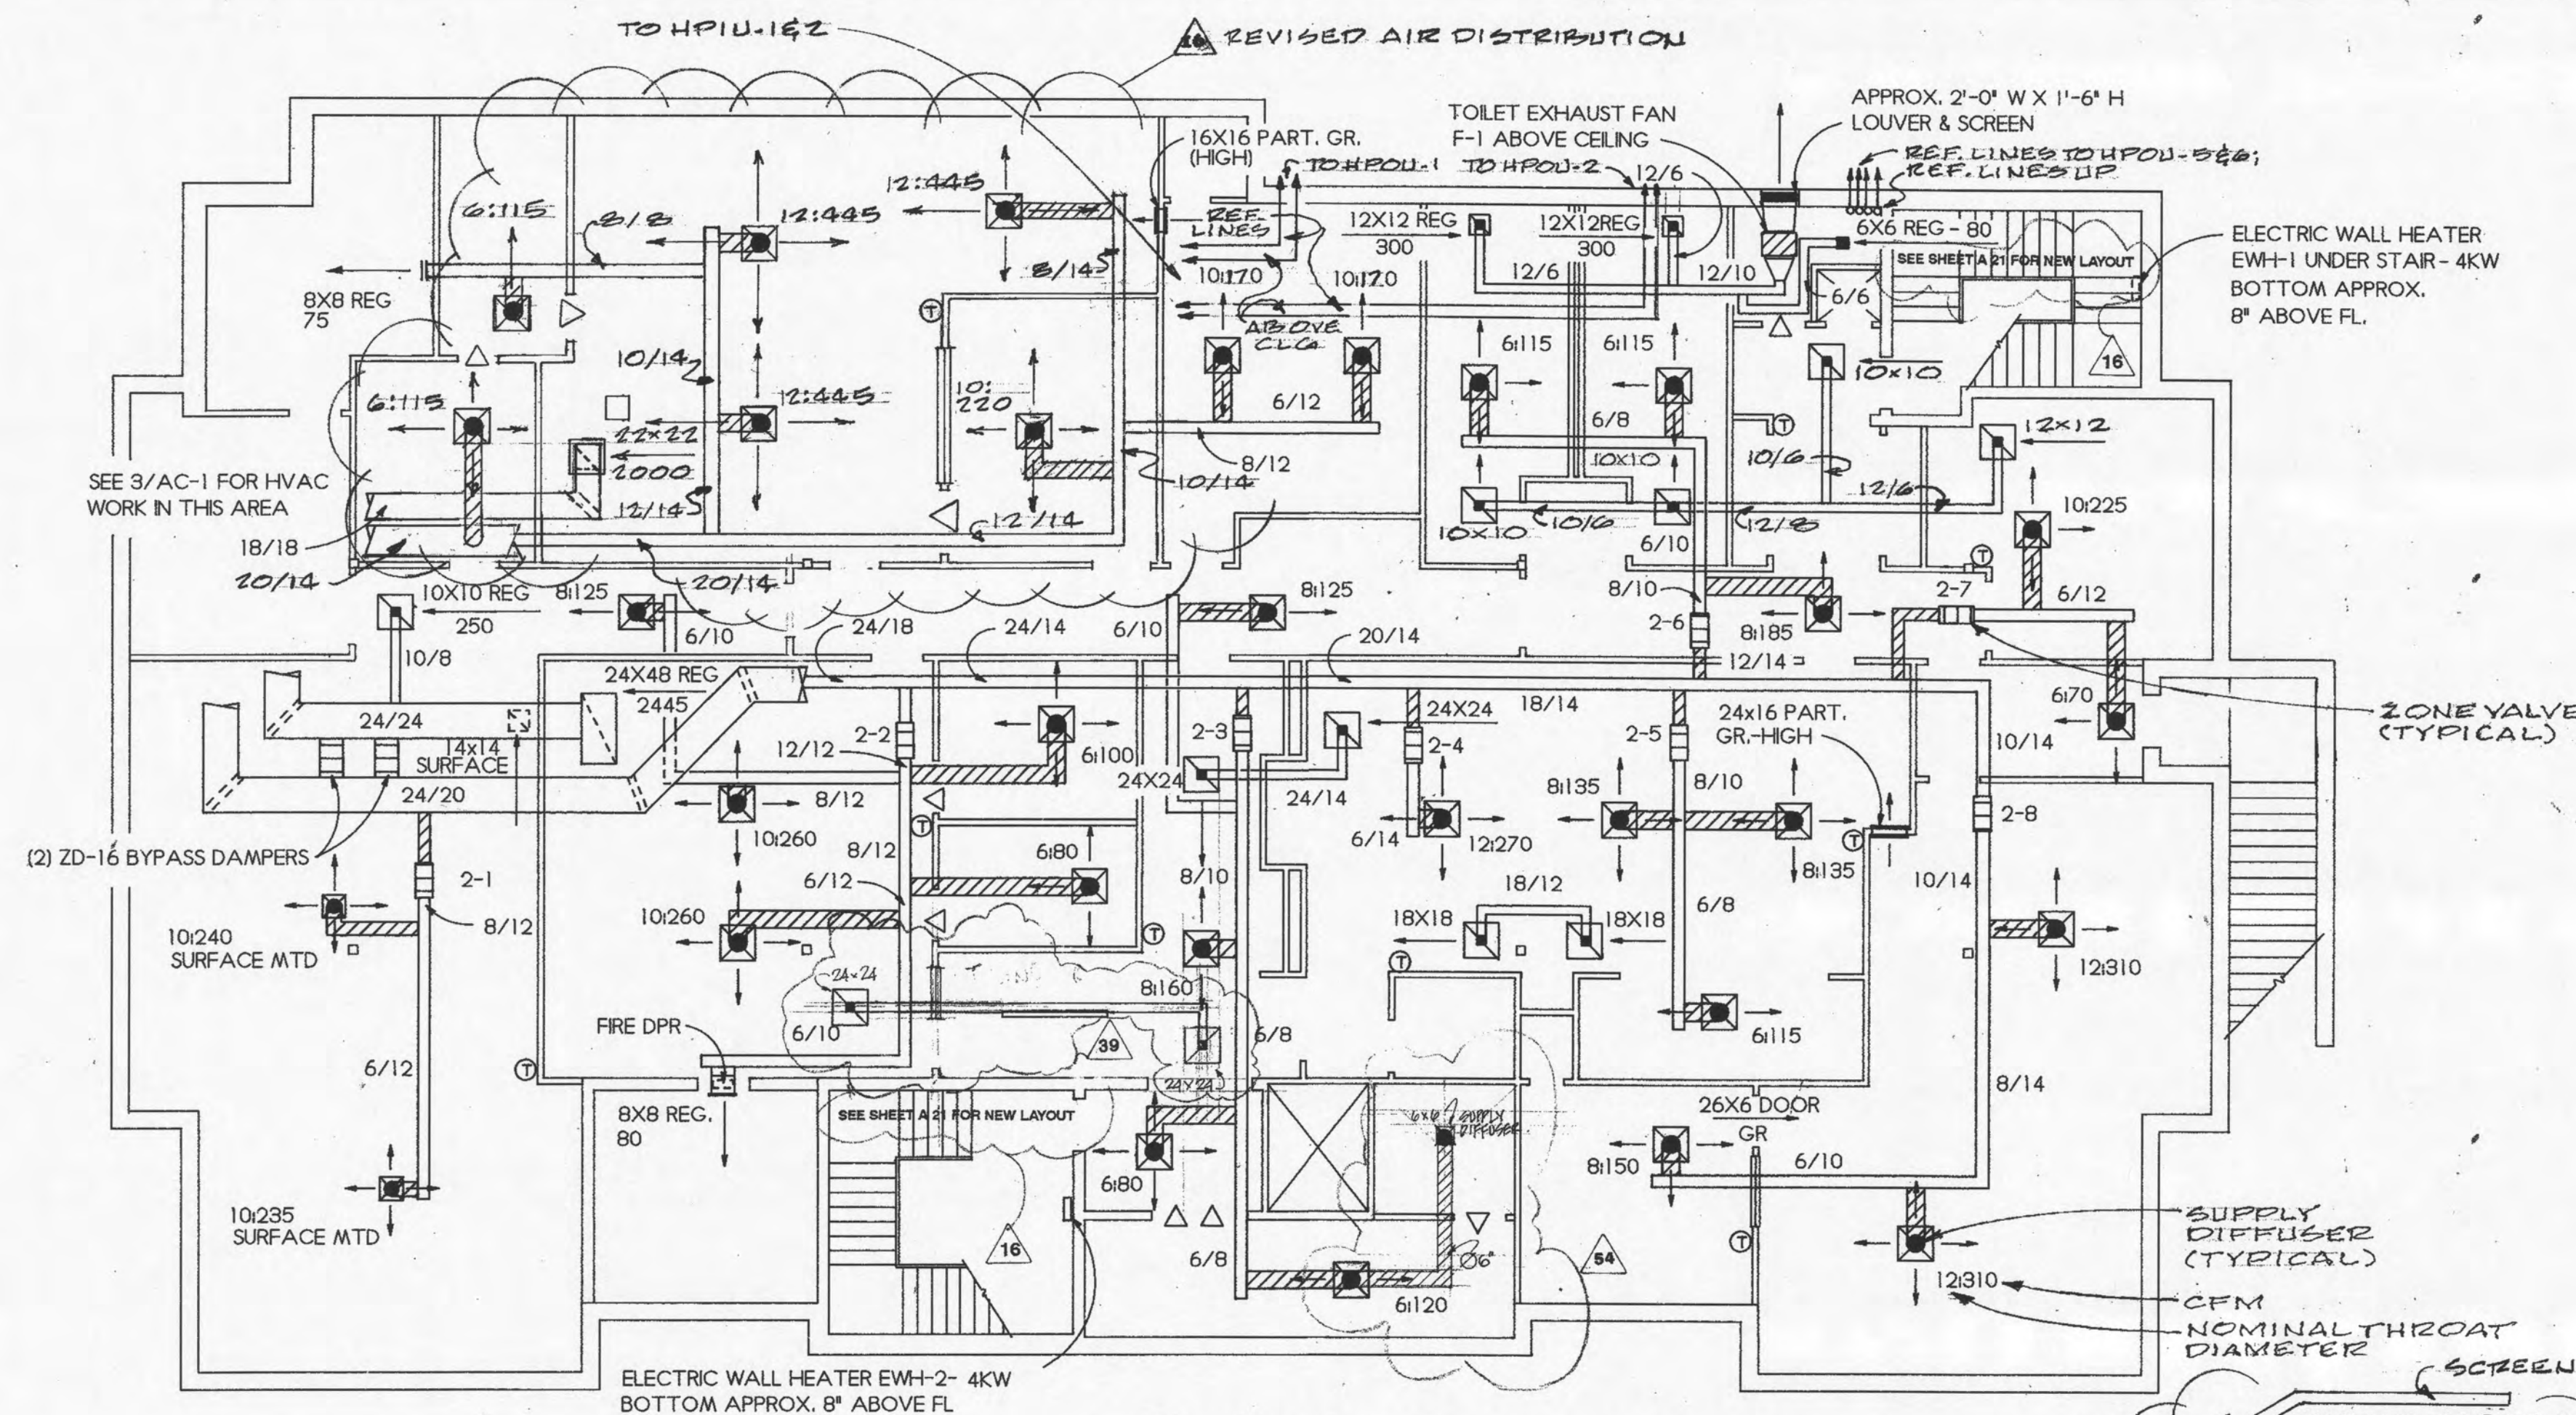


1 HVAC PLAN - LEVEL I
AC-1 1/8"=1'-0"

REFRIGERANT LINES UNDERGROUND TO HPOU'S. COVER W/ 3/4" INS. OR EQUAL.

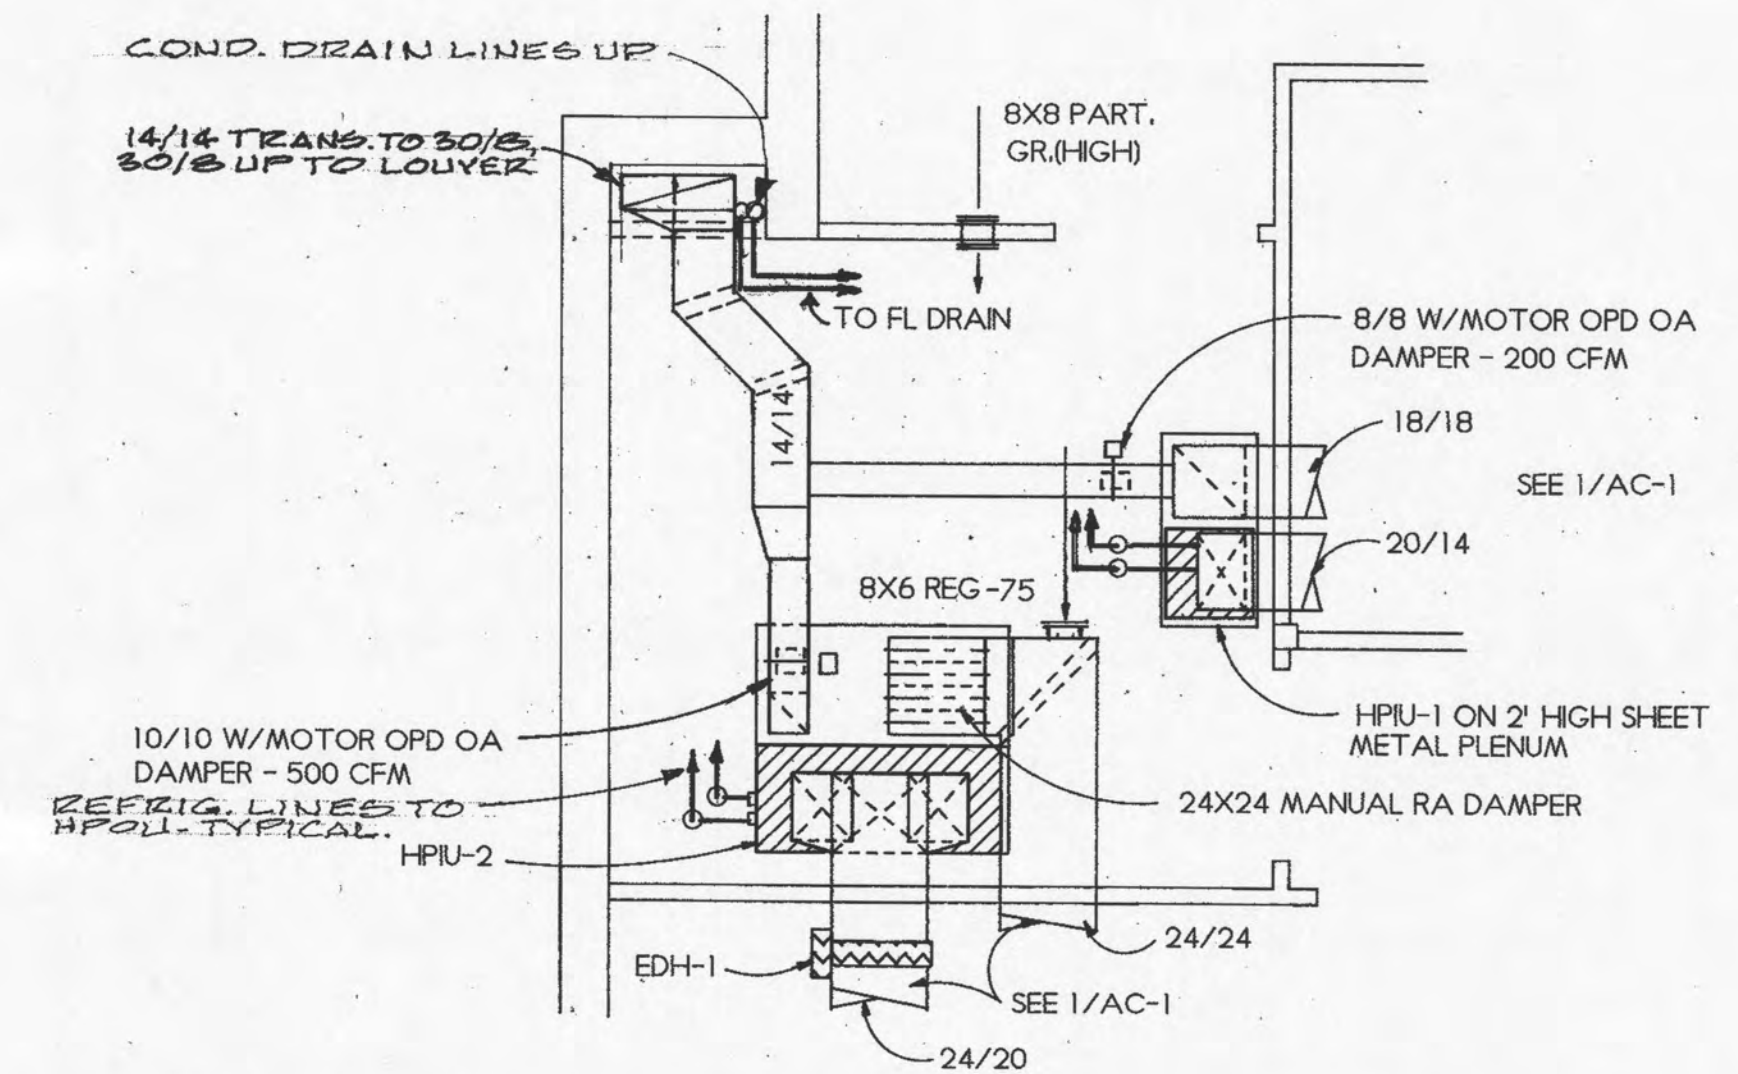


3 PART PLAN - LEVEL I MECH. ROOM
AC-1 1/4"=1'-0"

- GENERAL NOTES**
1. DUCTS CONNECTING TO TRANSFER GRILLES TO BE FULL SIZE OF GRILLE COLLAR UNLESS OTHERWISE NOTED.
 2. LAYOUT OF CEILING OUTLETS IS APPROXIMATE. SEE REFLECTED CEILING PLANS FOR ACTUAL LOCATIONS.
 3. SYMBOL Δ INDICATES 3/4" DOOR UNDERCUT.

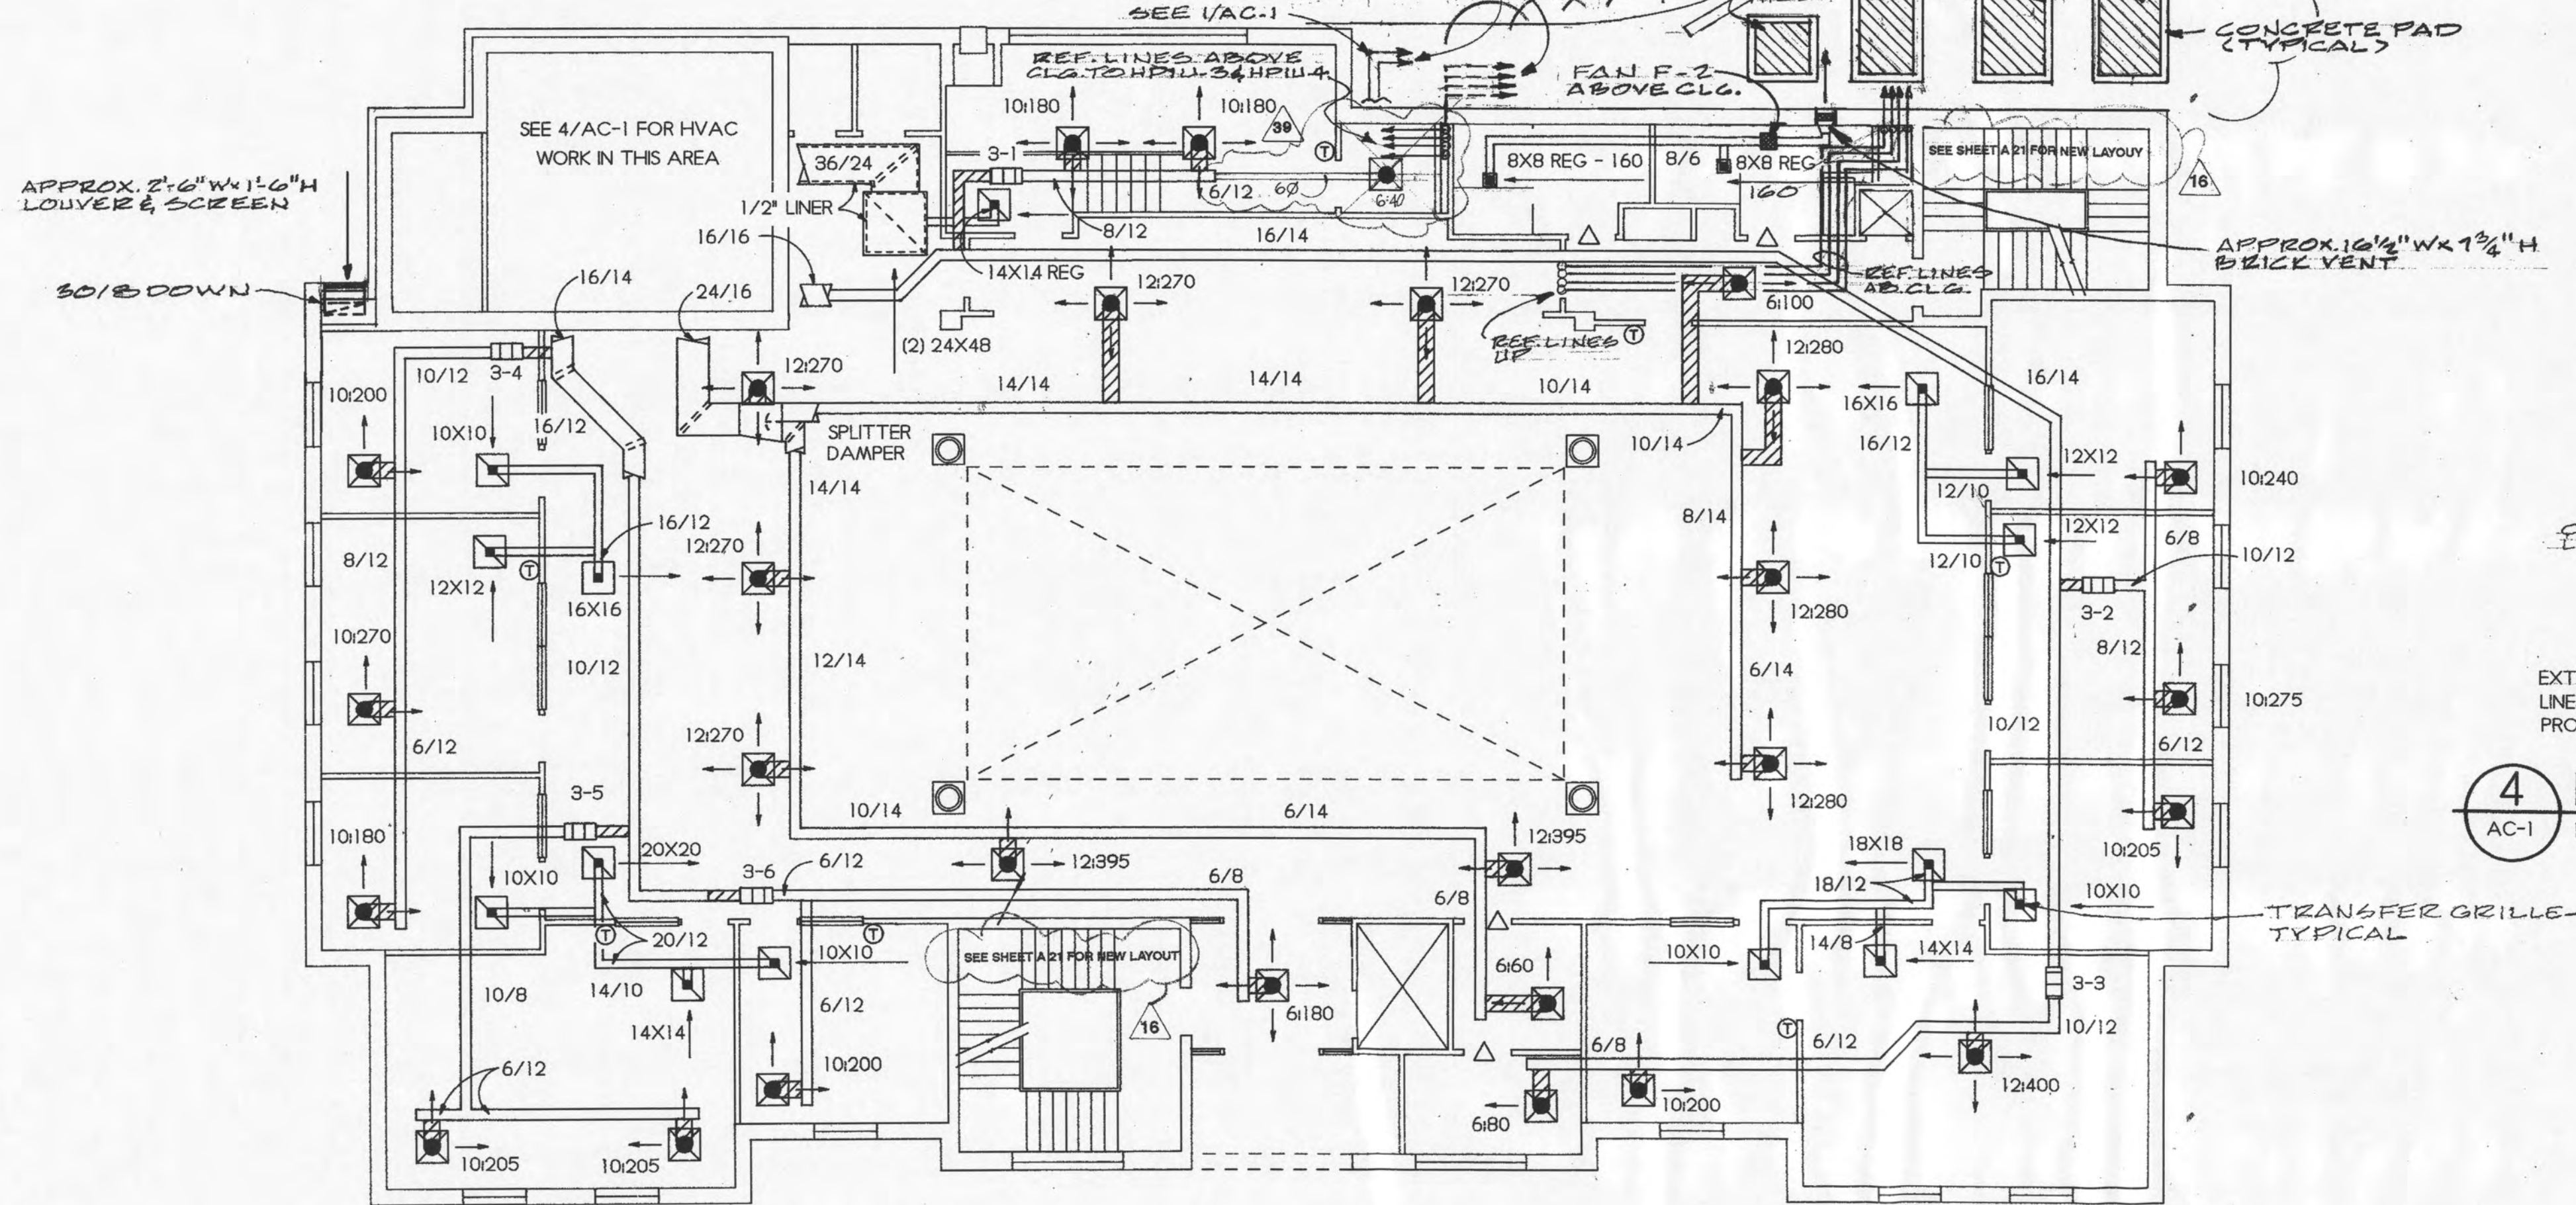

2 HVAC PLAN - LEVEL II
AC-1 1/8"=1'-0"

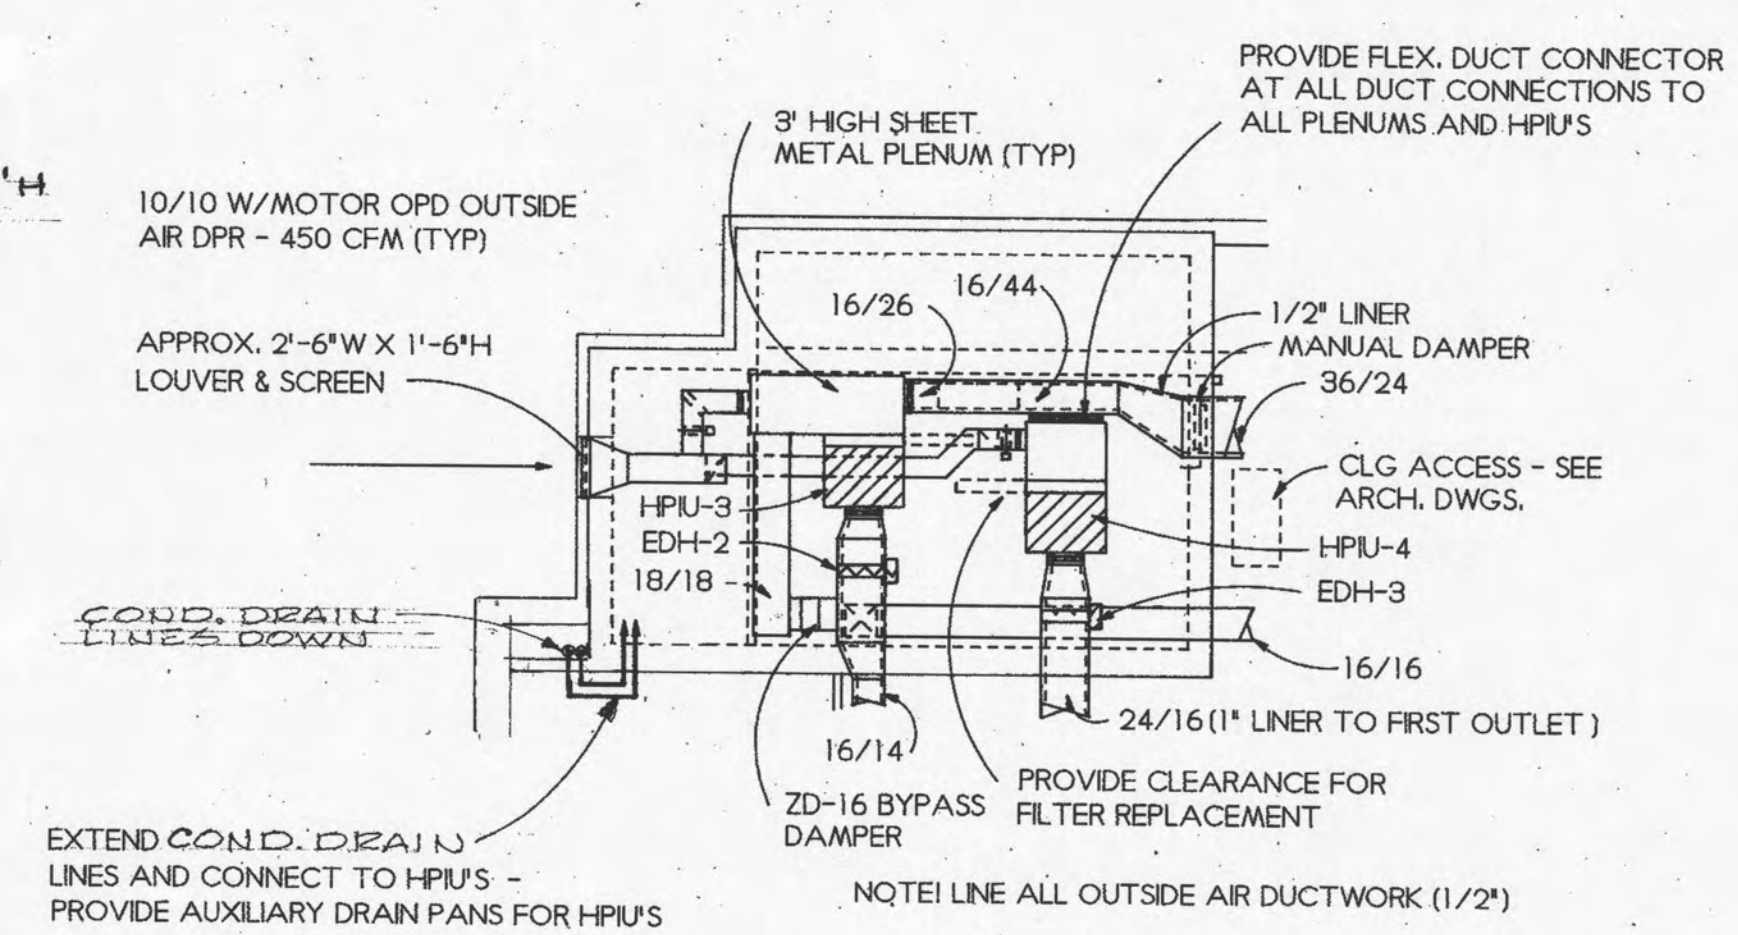

4 PART PLAN - MECH. SPACE OVER VAULT
AC-1 1/8"=1'-0"



VAL/TEC ENTERPRISES
125 E. TRINITY PLACE, SUITE 303
DECATUR, GEORGIA 30030
(404) 371-1040



Job No.	343
Revised	
September 9/92	15
December 14/92	30
March 2, 1993	38 RV
April 10/93	84 RV
checked by	RHW
drawn by	RHW

design-build
design-build
design-build

Concepts

300 Broadview
P.O. Box 1007
Pine Grove, MD
410-256-0801


• Consultants
• Designers
• Construction Managers

RELEASED FOR CONSTRUCTION


This drawing and the design of the mechanical room part plans are the property of Design/Build Concepts, Inc. The drawings are to be used only for the project and location specified on the drawing. Any other use without the written consent of Design/Build Concepts, Inc. is prohibited.

LEVEL I/II HVAC PLANS
MECHANICAL ROOM PART PLANS


NEW MAIN OFFICE FACILITIES FOR:
Bank of Roane County
HARRISMAN, TENNESSEE

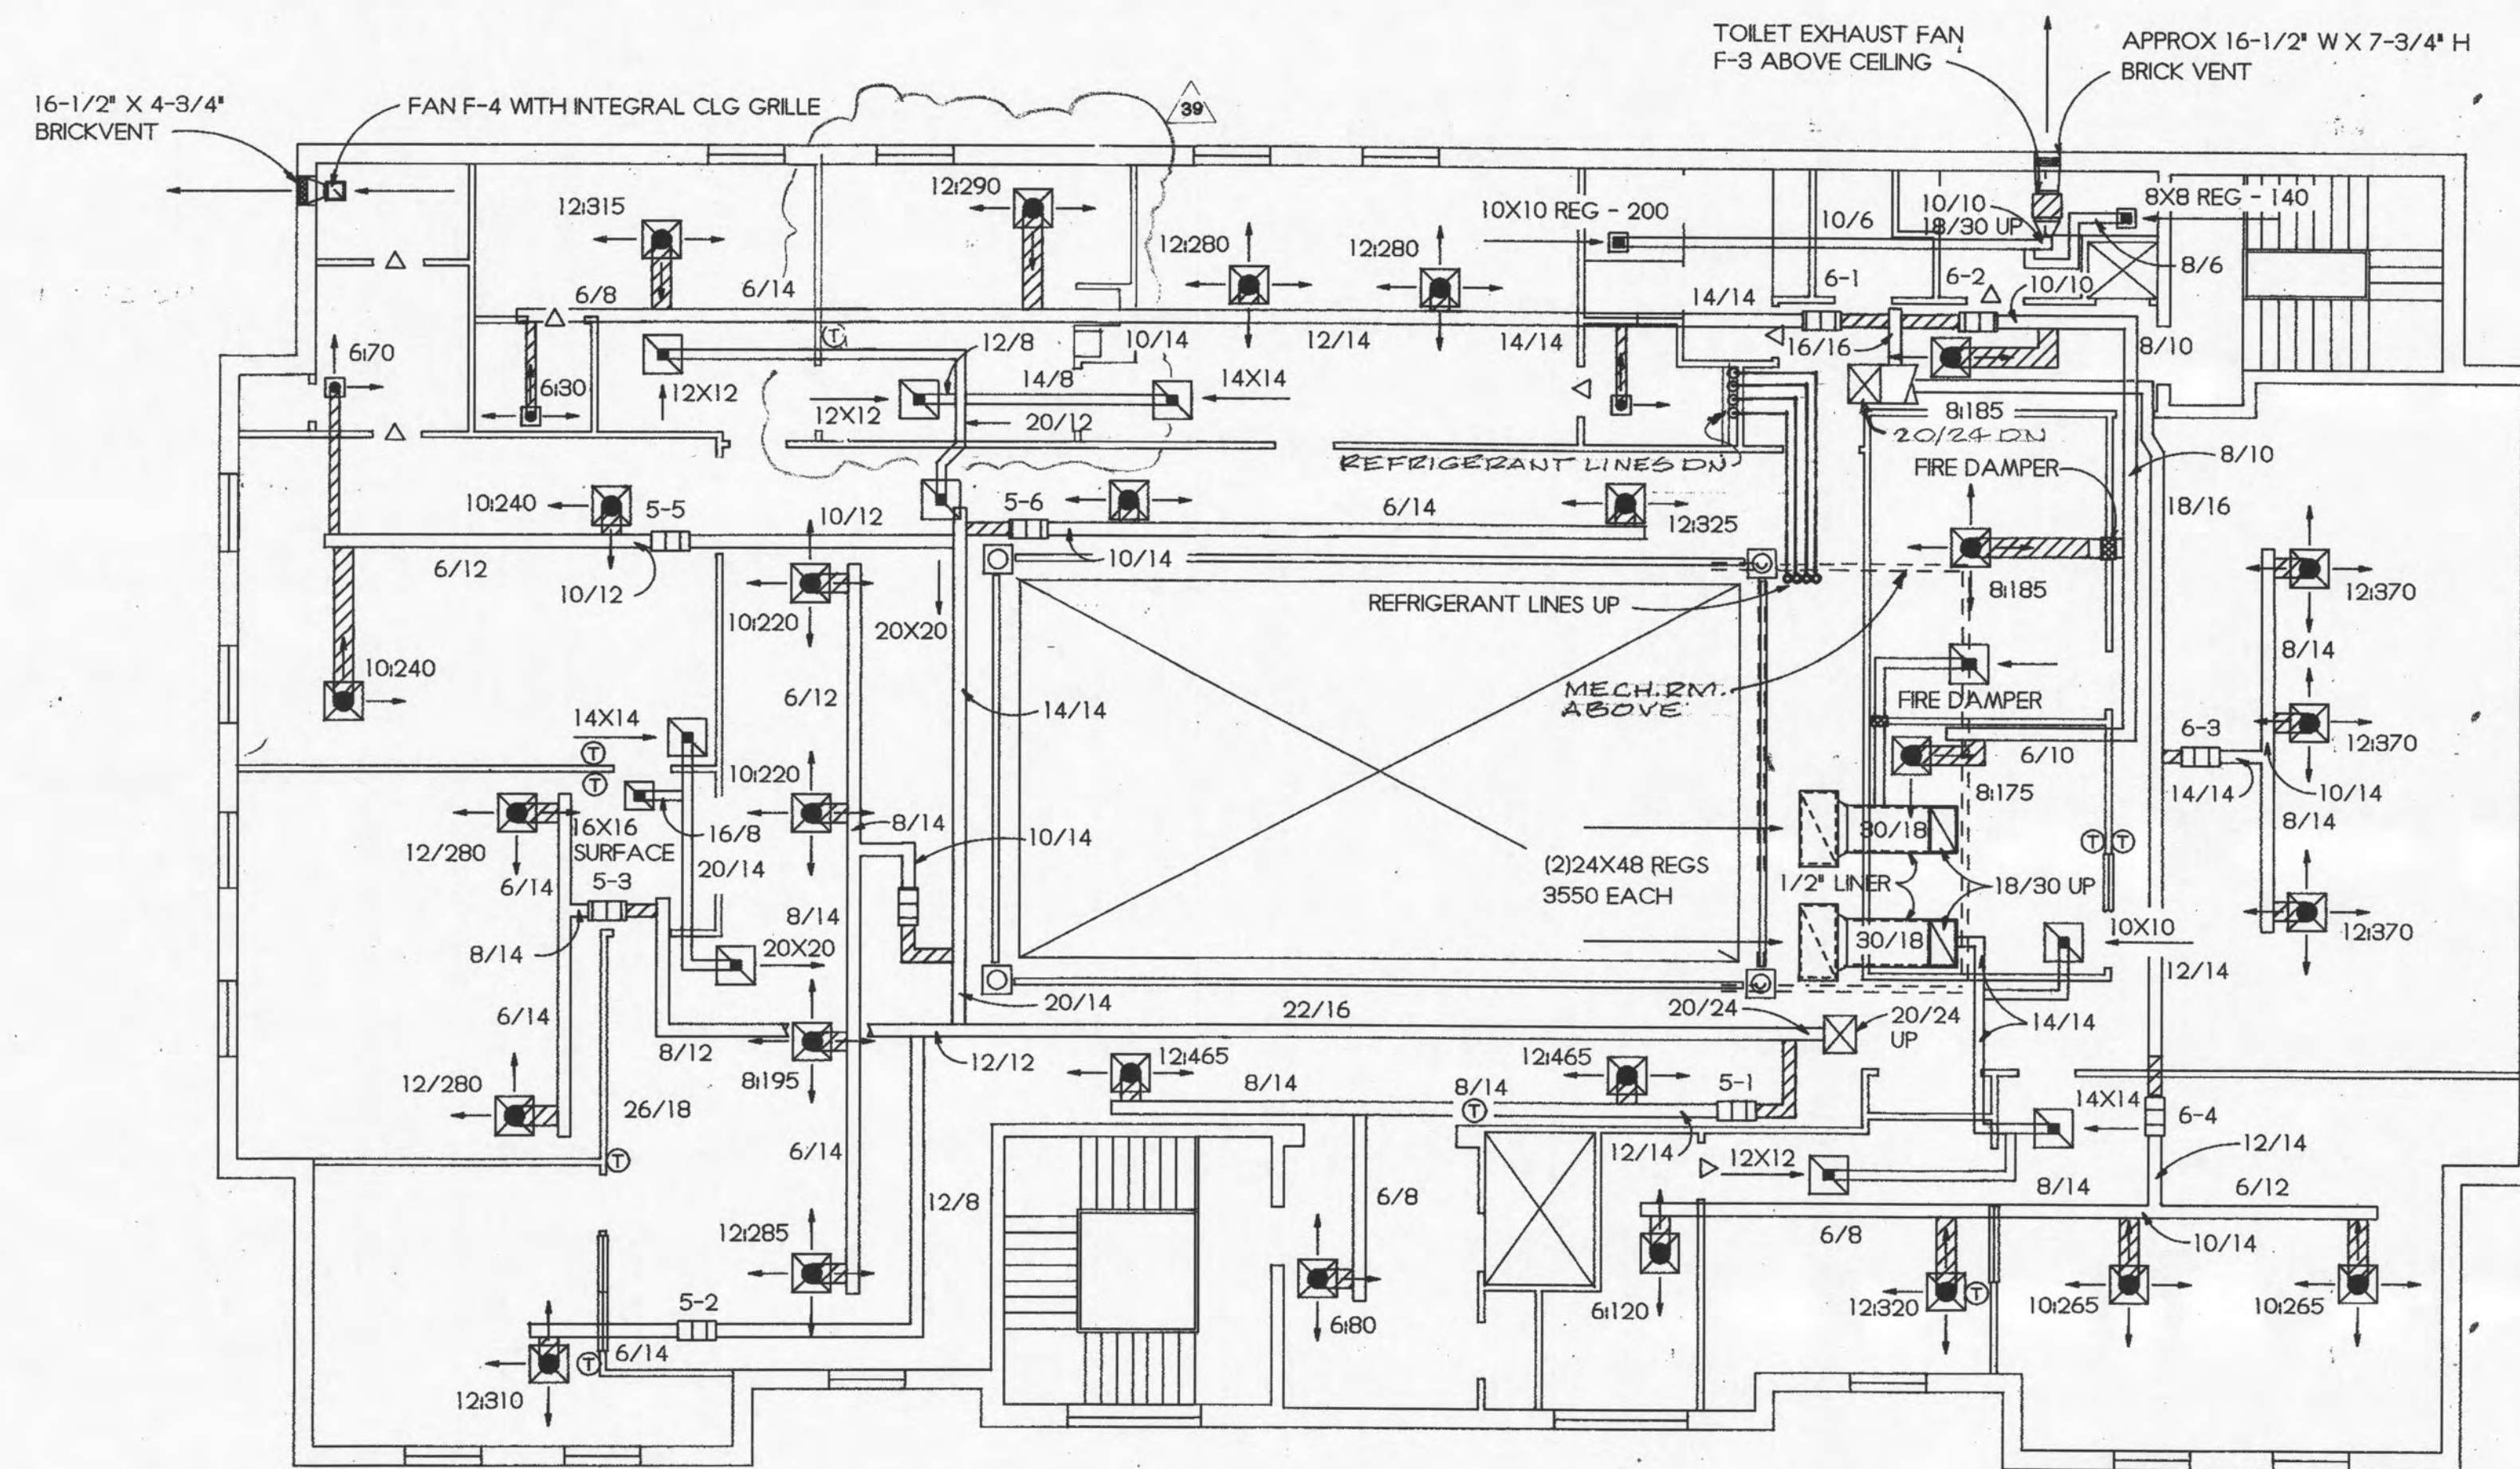


1 HVAC PLAN - LEVEL III
AC-2 1/8"=1'-0"

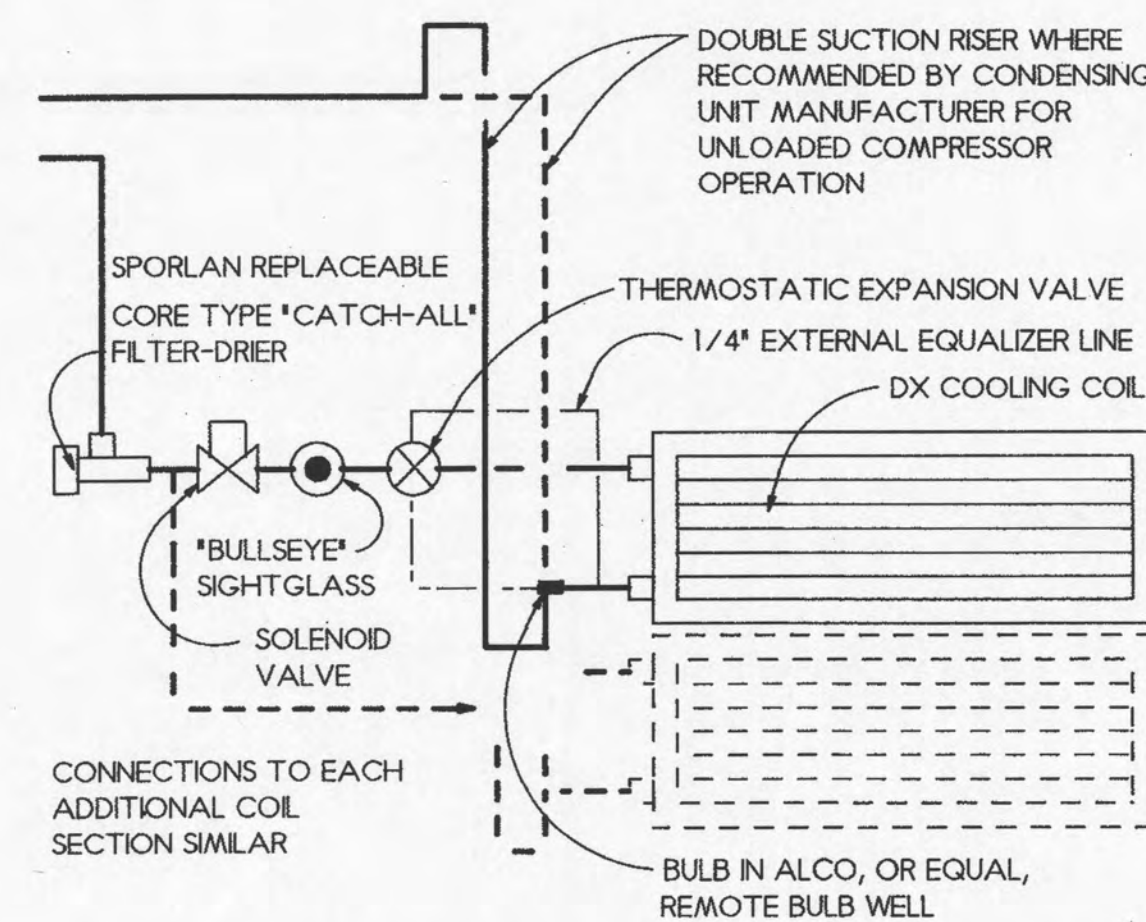

3 DX COIL CONNECTIONS
AC-2 SCHEMATIC ONLY
NOTE: MODIFY CONNECTIONS AS RECOMMENDED BY EQUIPMENT MANUFACTURER FOR HEAT PUMP OPERATION

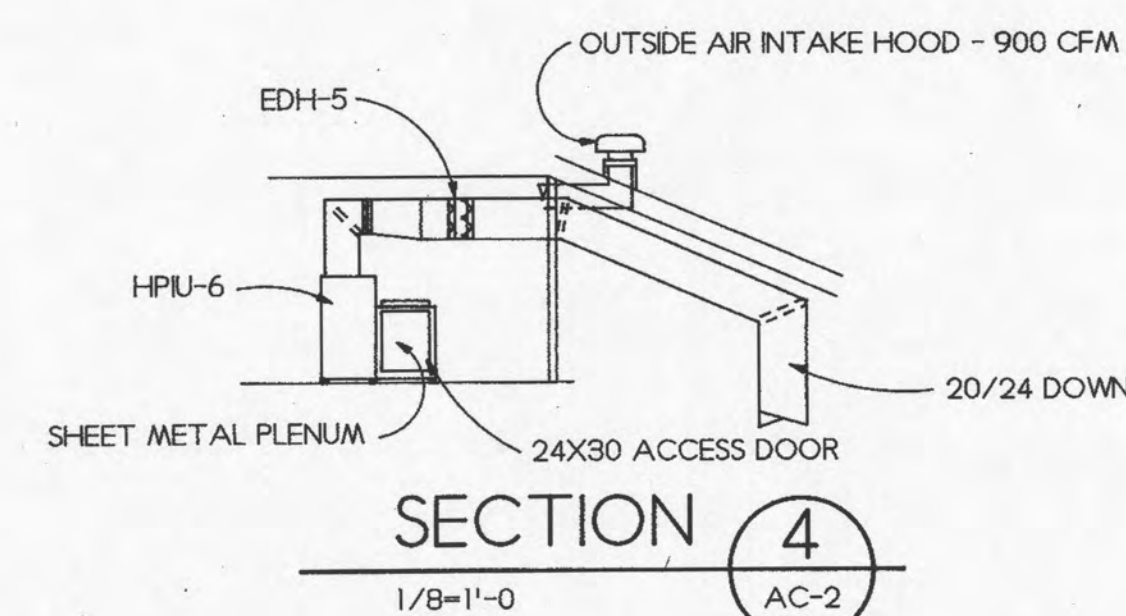

SECTION 4
1/8"=1'-0" AC-2

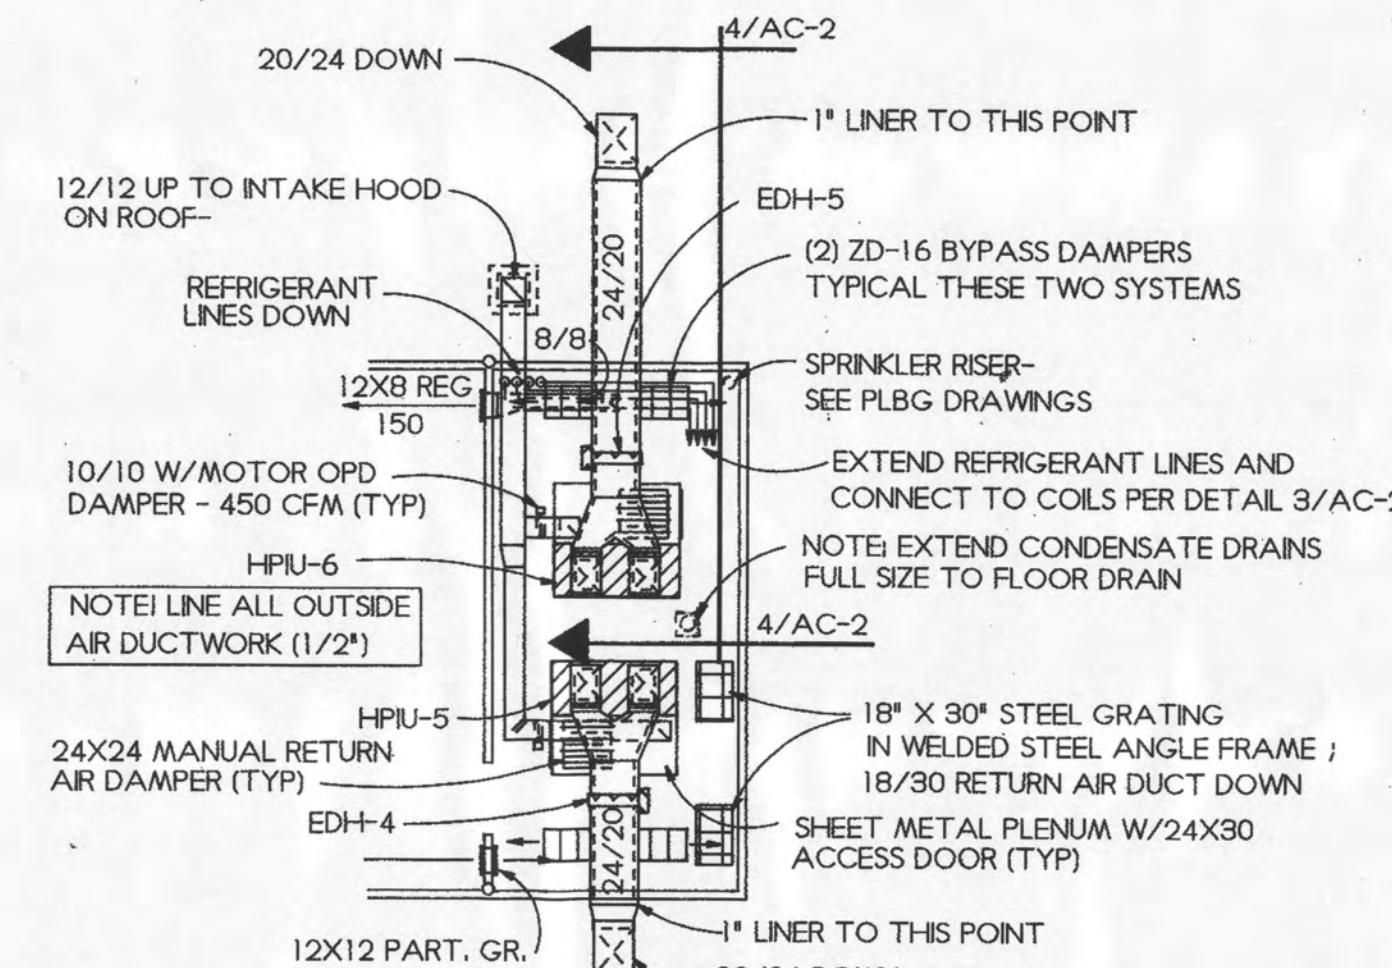

2 PART PLAN - ATTIC MECH. SPACE
AC-2 1/8"=1'-0"

FANS							
TAG	DESCRIPTION/ BASIS OF DESIGN	DRIVE	CFM	S.P. IN. W.G.	MAX. RPM	NOMINAL DIAMETER	APPROX. H. P.
F-1	PENN ZEPHYR Z12 CLG EXHAUSTER	DIRECT	680	0.375	1200	---	1/3
F-2	PENN ZEPHYR Z10 CLG EXHAUSTER	DIRECT	320	0.250	1200	---	1/6
F-3	PENN ZEPHYR Z10 CLG EXHAUSTER	DIRECT	340	0.250	1200	---	1/6
F-4	PENN ZEPHYR Z6 CLG EXHAUSTER	DIRECT	90	0.125	1200	---	1/12

- ① FOR IN-LINE INSTALLATION ② PROVIDE ACCESSORY BRICK VENT
③ PROVIDE ACCESSORY CEILING GRILLE

HEAT PUMP INDOOR UNITS

TAG	CONFIGURATION	CFM	S.P. ①	DX COOLING COIL				NOTES
				CAPACITY BTU/HR	MIN.F.A. SQ.FT.	ENT D.B.	LVG D.B.	
HPIU-1	VERT. DRAWTROUGH	2000	0.35	56,000	5.7	80	67	②
HPIU-2	VERT. DRAWTROUGH	4000	0.80	120,000	10.0	80	67	
HPIU-3	HORIZ. DRAWTROUGH	3100	0.80	88,000	6.9	80	67	
HPIU-4	HORIZ. DRAWTROUGH	3000	0.80	84,000	6.7	80	67	
HPIU-5	VERT. DRAWTROUGH	4000	0.80	120,000	10.0	80	67	
HPIU-6	VERT. DRAWTROUGH	4000	0.80	120,000	10.0	80	67	

- ① STATIC PRESSURE INDICATED IS EXTERNAL STATIC PRESSURE
② CAPACITY BASED ON ASSUMED COMPUTER EQUIPMENT HEAT RELEASE OF 3KW - VERIFY BEFORE ORDERING HPIU-1/HPIU-2

HEAT PUMP OUTDOOR UNITS

TAG	OPERATES IN CONJUNCTION WITH	MIN. COOLING CAPACITY (ARI)	MIN. HTG. CAP. BTU/HR ②	MAX. COMP. INPUT, KW ③	BASIS FOR DESIGN	NOTES
HPOU-1	HPIU-1	56,000 BTU/HR	27,000	4 ④	CARRIER 38YKB060	
HPOU-2	HPIU-2	120,000 BTU/HR	45,000	10.5	CARRIER 38AQ012	
HPOU-3	HPIU-3	88,000 BTU/HR	33,000	8.2	CARRIER 38BQ008	
HPOU-4	HPIU-4	84,000 BTU/HR	33,000	8.2	CARRIER 38BQ008	
HPOU-5	HPIU-5	120,000 BTU/HR	45,000	10.5	CARRIER 38AQ012	
HPOU-6	HPIU-6	120,000 BTU/HR	45,000	10.5	CARRIER 38AQ012	

- ① AT INDOOR COIL
② AT 0 DEG F OUTSIDE AMBIENT TEMP., 65 DEG F INDOOR AIR (INTEGRATED)
③ COMPRESSOR INPUT AT DESIGN COOLING CONDITIONS, UNLESS OTHERWISE NOTED
④ TOTAL SYSTEM INPUT

ZONE VALVES

TAG	CFM	MAX. VELOCITY, FPM	MAX. PRESSURE DROP, IN. W.G.	BASIS FOR DESIGN	NOMINAL DIA., INCHES	REMARKS
2-1	475	1200	.05	CARRIER/PARKER ZD-XX	10	
2-2	905				12	
2-3	485				10	
2-4	270				8	
2-5	385				8	
2-6	415				8	
2-7	295				8	
2-8	770				12	
3-1	360				8	
3-2	720				12	
3-3	680				12	
3-4	650				10	
3-5	410				8	
3-6	280				8	
5-1	1010				14	
5-2	310				8	
5-3	560				10	
5-4	920				12	
5-5	550				10	
5-6	650				10	
6-1	1225				14	
6-2	545				10	
6-3	1110				14	
6-4	970				14	

ELECTRIC DUCT HEATERS

TAG	OPERATES WITH	CAPACITY	NUMBER OF STEPS ①	REMARKS
EDH-1	HPIU-2	16KW	2	
EDH-2	HPIU-3	18KW	3	
EDH-3	HPIU-4	4KW	2	
EDH-4	HPIU-5	6KW	2	
EDH-5	HPIU-6	12KW	2	

- ① EQUAL 3 PHASE STEPS UNLESS OTHERWISE NOTED

VAL/TEC ENTERPRISES
125 E. TRINITY PLACE, SUITE 303
DECATUR, GEORGIA 30030
(404) 371-1040



Job No.	3472
Drawn by	RRW
Checked by	RRW
Date	March 2, 1992
Rev	39

Concepts
design-build
design-build
design-build

Consultants
Designers
Construction Managers

3000 Road Road
P.O. Box 1000

RELEASED FOR CONSTRUCTION
This document is the property of
Val/Tec Enterprises, Inc. It is to be
used for the project and no part
of it is to be reproduced or
transmitted in any form or by
any means, electronic, mechanical,
photocopying, recording, or by
any information storage and
retrieval system, without the
written permission of Val/Tec
Enterprises, Inc.

LEVEL III HVAC PLAN
SCHEDULES & DETAILS

NEW MAIN OFFICE FACILITIES FOR:
Bank of Roane County
HARRISMAN, TENNESSEE

JUNE 10, 1992

AC-2
of 2 sheets

CARTER STREET

ROANE STREET

PROPOSED BUILDING

TRENTON STREET

MORGAN STREET

ELECTRICAL SITE PLAN
SCALE 1"=1'-0"

CO-ORD EXACT LOCATION OF SIGN WITH OWNER PRIOR TO ROUGH-IN.

RUN 1 1/2" E.C. FOR SIGN. CO-ORD. REQUIREMENTS FOR SIGN, BREAKER SIZE, & WIRE SIZE PRIOR TO ROUGH-IN. RUN 3/4" E.C. WITH PULL WIRE TO MARKETING DEPT. AS DIRECTED BY OWNER (COMPUTER/SIGN).

MAIN TELEPHONE BACKBOARD

MAIN DISTRIBUTION PANEL "MDP"

PROPOSED LOCATION OF POWER CO. PAD MID. TRANSFORMER. 120/208V-3P-4W. CO-ORD. EXACT LOCATION, DETAILS AND METERING WITH THE POWER COMPANY. POWER COMPANY CONTACT IS CHUCK FLORA - (615) 882-9242.


30' FOR ENTIRE CKT. CONTROLLED VIA PHOTOCELL (ON ROOF) LIA-18

(1) 4" PVC CONDUIT WITH PULL WIRES TO PROPERTY LINE FOR TELEPHONE SERVICE. STUB-UP 3'-0" ABOVE GROUND AND CAP. CO-ORD. LOCATION AND DETAILS WITH THE TELEPHONE COMPANY. CONTACT AT TEL. CO. IS KEN WHITLOCK. (615) 699-9696

LEGEND

- HOMERUN TO PANELBOARD, LETTER INDICATES PANEL DESIGNATION, NUMBER INDICATES CIRCUIT NUMBER, SLASH MARKS INDICATES NUMBER OF CONDUCTORS IN SIZE CONDUIT AS REQUIRED BY NEC (NO SLASH MARKS INDICATES (2) #12, (1) #12-1/2" C). (✓) INDICATES GREEN GROUND CONDUCTOR.
- CONDUIT CONCEALED IN CEILING OR WALL.
- CONDUIT CONCEALED IN SLAB OR BELOW GRADE.
- TELEPHONE OR DATA CONDUIT CONCEALED IN SLAB OR BELOW GRADE. RUN 1" E.C. WITH PULL WIRE TO NEAREST WALL AND STUB-UP 6" INTO CEILING SPACE. PROVIDE BUSHED OPENING AT STUB-UP.
- ALARM CONDUIT CONCEALED IN SLAB OR BELOW GRADE. RUN 3/4" E.C. WITH PULL WIRE TO NEAREST WALL AND STUB-UP 6" INTO CEILING SPACE. PROVIDE BUSHED OPENING AT STUB-UP.
- CONDUIT EXPOSED.
- CIRCUIT BREAKER IN NEMA 1 ENCLOSURE.
- MAIN DISTRIBUTION PANEL, 120/208V - 3 PHASE - 4 WIRE.
- PANELBOARD, 120/208V - 3 PHASE - 4 WIRE.
- CONTROLLER.
- DISCONNECT SWITCH, F INDICATES FUSED, WP INDICATES WEATHERPROOF NEMA 3R. MOTOR, HP INDICATED.
- FLUORESCENT FIXTURE, TYPE INDICATED.
- FLUORESCENT FIXTURE, TYPE INDICATED.
- FLUORESCENT FIXTURE, NIGHT LIGHT WITH BODINE BATTERY INVERTOR.
- INCANDESCENT OR HID FIXTURE, TYPE INDICATED, WALL MOUNTED.
- INCANDESCENT OR HID FIXTURE, TYPE INDICATED, CEILING MOUNTED.
- INCANDESCENT OR HID NIGHT LIGHT FIXTURE, TYPE INDICATED.
- INCANDESCENT WALL WASH LIGHT FIXTURE, TYPE INDICATED.
- PARKING LOT LIGHT, TYPE INDICATED.
- GROUND MOUNTED FLOODLIGHT, TYPE INDICATED.
- EXIT SIGN WITH BATTERY BACK-UP, LITHONIA CAT. NO. F2ES1R-120-EL.
- EMERGENCY BATTERY LIGHT, NUMBER OF HEADS INDICATED, LITHONIA CAT. NO. ELM-2.
- TOGGLE SWITCH, 2 INDICATES 2 POLE, 3 INDICATES 3 WAY, 4 INDICATES 4 WAY, P INDICATES PILOT LIGHT, M INDICATES MANUAL MOTOR CONTROLLER.
- DIMMER SWITCH, LUTRON NOVA SERIES. SIZED FOR LOAD.
- DUPLEX RECEPTACLE - MOUNT AT 18" A.F.F.
- DUPLEX RECEPTACLE ABOVE COUNTER TOP. MOUNT AT 42" A.F.F.
- GROUND FAULT INTERRUPTER DUPLEX RECEPTACLE. MOUNT AT 18" A.F.F. UNLESS NOTED OTHERWISE.
- ISOLATED GROUND DUPLEX RECEPTACLE, MOUNT 18" A.F.F.
- DOUBLE DUPLEX RECEPTACLE, MOUNT 18" A.F.F.
- FLOOR OUTLET (2 GANG BOX) FOR 20 AMP DUPLEX RECEPTACLE AND 20 AMP ISOLATED GROUND RECEPTACLE STEEL CITY #680 SERIES WITH GRAYCARPET PLATE.
- SPECIAL OUTLET-COORDINATE WITH EQUIPMENT FURNISHED. MOUNT AT 18" A.F.F. UNLESS NOTED OTHERWISE.
- JUNCTION BOX.
- THERMOSTAT.
- FIRE ALARM CONTROL PANEL, NOTIFIER CAT. NO. 5000 SERIES S.
- HORN STROBE UNIT, NOTIFIER CAT. NO. GX90S-4HWR.
- VISUAL STROBE UNIT, NOTIFIER CAT. NO. GXS-4HWR.
- MANUAL PULL STATION, NOTIFIER CAT. NO. BNG-1R.
- SPRINKLER WATER FLOW SWITCH (FURNISHED BY OTHERS).
- SPRINKLER VALVE TAMPER SWITCH (FURNISHED BY OTHERS).
- DUCT DETECTOR, NOTIFIER CAT. NO. DH-22 HOUSING W/PSD-7129 DETECTOR HEAD.
- SMOKE DETECTOR, NOTIFIER CAT. NO. 2451 W/401B BASE.
- ELECTRIC DUCT HEATER.
- TELEPHONE OR DATA OUTLET. PROVIDE SINGLE GANG BOX 18" A.F.F. AND RUN 3/4" E.C. WITH PULL WIRE INTO CEILING SPACE. PROVIDE BUSHED OPENING AT STUB-UP.
- TELEPHONE AND DATA OUTLET. PROVIDE SINGLE GANG BOX 18" A.F.F. AND RUN 3/4" E.C. WITH PULL WIRE INTO CEILING SPACE. PROVIDE BUSHED OPENING AT STUB-UP.
- TELEPHONE AND DATA OUTLET. PROVIDE TWO GANG BOX 18" A.F.F. AND RUN 1" E.C. WITH PULL WIRE INTO CEILING SPACE. PROVIDE BUSHED OPENING AT STUB-UP.
- CAMERA OUTLET, RUN 3/4" E.C. WITH PULL WIRE INTO CEILING SPACE. PROVIDE BUSHED OPENING AT STUB-UP. CO-ORD MOUNTING HEIGHTS WITH ARCH. PRIOR TO ROUGH IN.
- ALARM OUTLET, RUN 3/4" E.C. WITH PULL WIRE INTO CEILING SPACE. PROVIDE BUSHED OPENING AT STUB-UP. CO-ORD MOUNTING HEIGHTS WITH ARCH. PRIOR TO ROUGH IN.
- HEXAGON WITH NUMBER INSIDE REFERS TO DRAWING NOTE.
- RECESSED WALL BOX MOUNTED AT 2-1/2" AFF TO CENTER. FOR ATTACHMENT OF SYSTEM FURNITURE DATA AND TELEPHONE. CO-ORD. EXACT LOCATION WITH ARCH. PRIOR TO ROUGH IN.
- RECESSED WALL BOX MOUNTED AT 2-1/2" A.F.F. TO CENTER. FOR ATTACHMENT OF SYSTEM FURNITURE POWER WHIP. CO-ORD. EXACT LOCATION WITH ARCH. PRIOR TO ROUGH IN.
- TRIGGERING DEVICE FOR DYE ALARM.
- SILENT ALARM OUTLET, RUN 3/4" E.C. WITH PULL WIRE INTO CEILING SPACE AND STUB-UP 6". PROVIDE BUSHED OPENING AT STUB-UP.
- EMERGENCY POWER OFF BUTTON. (E.P.O.)

DATE 9-9-92

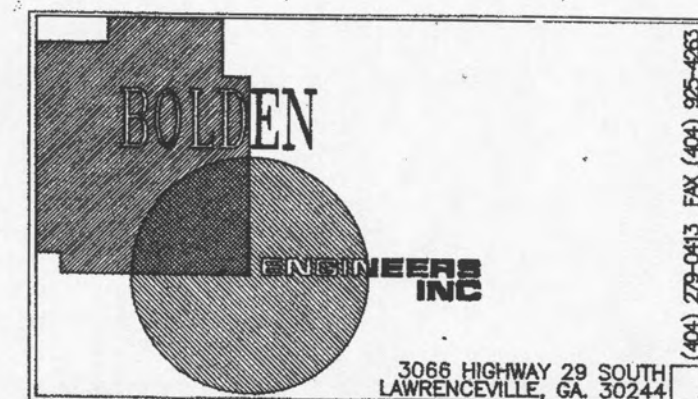

Sheet Description

ELECTRICAL SITE PLAN

A NEW MAIN OFFICE FACILITIES FOR:

Bank of Roane County
HARRIMAN, TENNESSEE

E-1

Sheet

of 25 SHEETS

RELEASED FOR CONSTRUCTION

This drawing and the designs herein are the sole property of BOLDEN ENGINEERS, INC. and shall not be reproduced or used in any manner without the written consent of BOLDEN ENGINEERS, INC. for any purpose other than that specifically authorized by writing is prohibited.

800740

Concepts
design-build
design-build
design-build
design-build

• Consultants
• Designers
• Construction Managers

1407 525 0500
3501 Round Road
Riverside, Georgia 30312



343	343
8/16	8/16
9/22	9/22
10/15	10/15
11/15	11/15
12/15	12/15
1/16	1/16
2/16	2/16
3/16	3/16
4/16	4/16
5/16	5/16
6/16	6/16
7/16	7/16
8/16	8/16
9/16	9/16
10/16	10/16
11/16	11/16
12/16	12/16
1/17	1/17
2/17	2/17
3/17	3/17
4/17	4/17
5/17	5/17
6/17	6/17
7/17	7/17
8/17	8/17
9/17	9/17
10/17	10/17
11/17	11/17
12/17	12/17
1/18	1/18
2/18	2/18
3/18	3/18
4/18	4/18
5/18	5/18
6/18	6/18
7/18	7/18
8/18	8/18
9/18	9/18
10/18	10/18
11/18	11/18
12/18	12/18
1/19	1/19
2/19	2/19
3/19	3/19
4/19	4/19
5/19	5/19
6/19	6/19
7/19	7/19
8/19	8/19
9/19	9/19
10/19	10/19
11/19	11/19
12/19	12/19
1/20	1/20
2/20	2/20
3/20	3/20
4/20	4/20
5/20	5/20
6/20	6/20
7/20	7/20
8/20	8/20
9/20	9/20
10/20	10/20
11/20	11/20
12/20	12/20
1/21	1/21
2/21	2/21
3/21	3/21
4/21	4/21
5/21	5/21
6/21	6/21
7/21	7/21
8/21	8/21
9/21	9/21
10/21	10/21
11/21	11/21
12/21	12/21
1/22	1/22
2/22	2/22
3/22	3/22
4/22	4/22
5/22	5/22
6/22	6/22
7/22	7/22
8/22	8/22
9/22	9/22
10/22	10/22
11/22	11/22
12/22	12/22
1/23	1/23
2/23	2/23
3/23	3/23
4/23	4/23
5/23	5/23
6/23	6/23
7/23	7/23
8/23	8/23
9/23	9/23
10/23	10/23
11/23	11/23
12/23	12/23
1/24	1/24
2/24	2/24
3/24	3/24
4/24	4/24
5/24	5/24
6/24	6/24
7/24	7/24
8/24	8/24
9/24	9/24
10/24	10/24
11/24	11/24
12/24	12/24
1/25	1/25
2/25	2/25
3/25	3/25
4/25	4/25
5/25	5/25
6/25	6/25
7/25	7/25
8/25	8/25
9/25	9/25
10/25	10/25
11/25	11/25
12/25	12/25
1/26	1/26
2/26	2/26
3/26	3/26
4/26	4/26
5/26	5/26
6/26	6/26
7/26	7/26
8/26	8/26
9/26	9/26
10/26	10/26
11/26	11/26
12/26	12/26
1/27	1/27
2/27	2/27
3/27	3/27
4/27	4/27
5/27	5/27
6/27	6/27
7/27	7/27
8/27	8/27
9/27	9/27
10/27	10/27
11/27	11/27
12/27	12/27
1/28	1/28
2/28	2/28
3/28	3/28
4/28	4/28
5/28	5/28
6/28	6/28
7/28	7/28
8/28	8/28
9/28	9/28
10/28	10/28
11/28	11/28
12/28	12/28
1/29	1/29
2/29	2/29
3/29	3/29
4/29	4/29
5/29	5/29
6/29	6/29
7/29	7/29
8/29	8/29
9/29	9/29
10/29	10/29
11/29	11/29
12/29	12/29
1/30	1/30
2/30	2/30
3/30	3/30
4/30	4/30
5/30	5/30
6/30	6/30
7/30	7/30
8/30	8/30
9/30	9/30
10/30	10/30
11/30	11/30
12/30	12/30
1/31	1/31
2/31	2/31
3/31	3/31
4/31	4/31
5/31	5/31
6/31	6/31
7/31	7/31
8/31	8/31
9/31	9/31
10/31	10/31
11/31	11/31
12/31	12/31



FURNISH AND INSTALL EMERGENCY GENERATOR SET KOHLER CAT. NO. 5FMY, PROPANE, OR APPROVED EQUAL RATED FOR CONTINUOUS STAND BY SERVICE AT 5KW, 60HZ, 120V-1PH. UNIT SHALL BE IN WEATHERPROOF HOUSING. PROVIDE ELECTRIC START WITH STARTING, BATTERY, 30/1 OUT PUT BREAKER ON GENERATOR, 120 GALLON PAD MOUNTED PROPANE TANK AND 30 AMP AUTOMATIC TRANSFER SWITCH KOHLER CAT. NO. K122231-0030. FURNISH NECESSARY INSTRUMENTS, ACCESSORIES AND CONTROLS TO MEET ALL APPLICABLE CODES AND TO MAKE SYSTEM COMPLETE.

FIRE ALARM SYSTEM ALTERNATE

COMPLETE SMOKE ALARM COVERAGE MAY NOT BE PROVIDED. GIVE ALTERNATE PRICE FOR DELETION OF ALL SMOKE DETECTORS INDICATED WITH ASTERISK. (5)*

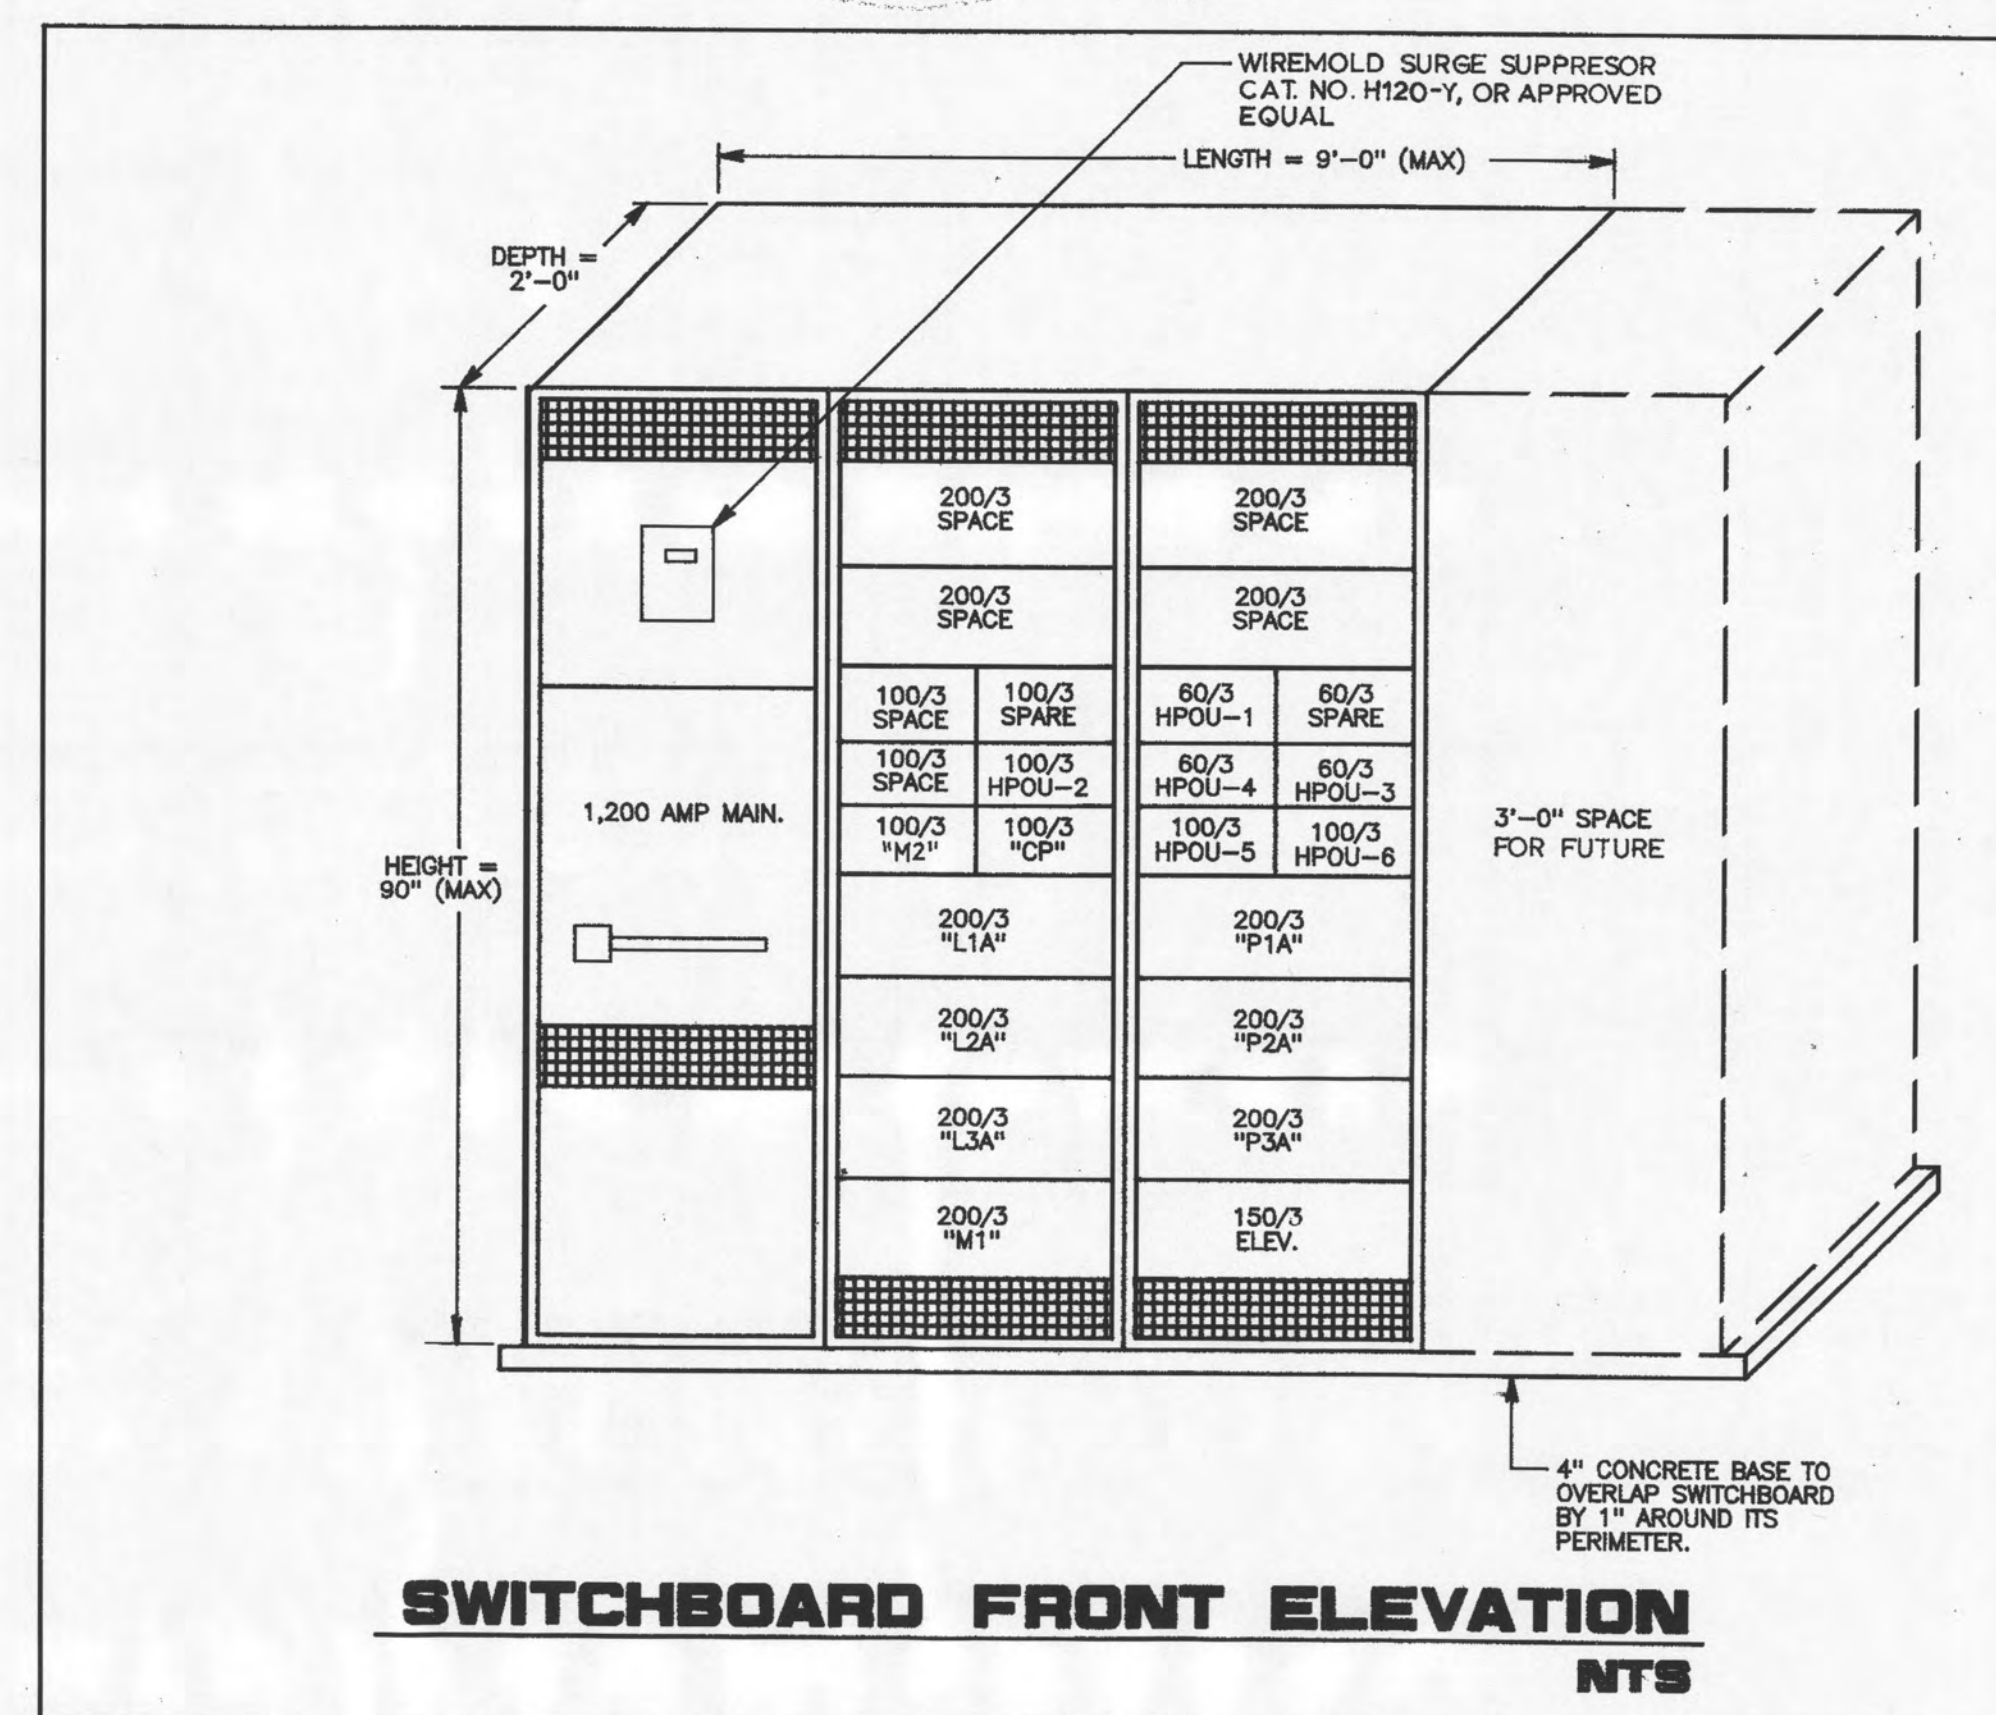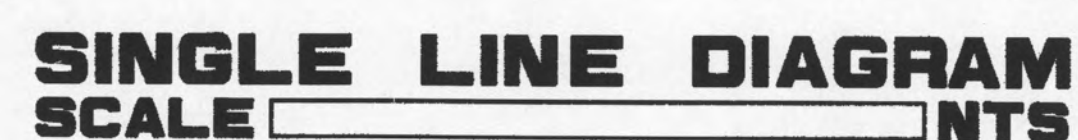

ELECTRICAL LOADS	
LIGHTING-	65.0 KW
RECEPTACLES-	98.1 KW
WATER HTR.-	9.0 KW
H.V.A.C.- HPOU'S (OUTDOOR)	93.3 KW
HPIU'S (INDOOR)	12.1 KW
DUCT HTRS.	56.0 KW
WALL HTRS.	8.0 KW
TOTAL CONNECTED LOAD=	345.50 KW
$\frac{345,000}{(208)(V)(1.73)} = 960.1 \text{ AMPS}$	

[illegible]

design build
design build
design build
design build

Concepts

- Consultants
- Designers
- Construction Managers

5870 Toulon Road
Ft. Worth, Texas 76137

RELEASED FOR CONSTRUCTION

The information contained herein is the sole property of Desig/Built Concepts, Inc. The information is not to be used in any form, by any means, in documents, in whole or in part, without the express written permission of Desig/Built Concepts, Inc. This release is specifically authorized by Desig/Built Concepts, Inc. in writing, as evidenced.

sheet description

SECURITY DIAGRAMS

A NEW MAIN OFFICE FACILITIES FOR:

Bank of Roane County
HARRIMAN, TENNESSEE

002 JUNE 19, 1992

Sheet

12


of 9 sheets

GENERAL NOTES

1. REFER TO ARCHITECTURAL REFLECTED CEILING PLAN FOR EXACT LOCATION OF ALL LIGHT FIXTURES.
2. FINAL AIMING OF ALL ADJUSTABLE LIGHT FIXTURES TO BE AS DIRECTED BY ARCHITECT.
3. REFER TO SINGLE LINE DIAGRAM FOR FEEDER SIZES FOR PANELBOARDS, HVAC EQUIPMENT AND ELEVATOR.
4. OVERCURRENT PROTECTION, WIRE SIZE AND NUMBER OF CONNECTION POINTS FOR MECHANICAL HVAC EQUIPMENT IS FOR ITEMS AS SPECIFIED. COORDINATE WITH MECHANICAL CONTRACTOR AND MAKE NECESSARY CHANGES PRIOR TO INSTALLATION FOR ACTUAL EQUIPMENT FURNISHED AT NO COST TO OWNER. REFER TO MECHANICAL DRAWINGS FOR EXACT LOCATION OF MECHANICAL EQUIPMENT.
5. ALL RECEPTACLES WITHIN (6) FEET OF PLUMBING FIXTURES SHALL BE PROVIDED WITH 5 MILLIAMP GROUND FAULT INTERRUPTERS.
6. CONFIRM MOUNTING HEIGHTS AND COORDINATE LOCATION OF ALL OUTLETS, SWITCHES AND OTHER DEVICES WITH ARCHITECTURAL ELEVATIONS (FURNITURE LAYOUT) PRIOR TO ROUGH-IN.
7. SMOKE DETECTORS SHALL BE LOCATED A MAXIMUM OF 30 FEET ON CENTER AND NO MORE THAN 15' FROM ENDS IN ALL CORRIDORS. SEE NOTE SHEET E-2.
8. ALL WIRING SHALL BE IN METAL CONDUIT.
9. ALL EMPTY CONDUIT TO CONTAIN PULL WIRES.
10. REFER TO DETAIL ON SHEET E-4 FOR LOCATION OF ALL LIGHT SWITCH WALL PLATES.
11. MAKE ALL ELECTRICAL CONNECTIONS REQUIRED FOR THE VISUAL DRIVE UP TELLER SYSTEM. ALL WORK SHALL BE IN STRICT COMPLIANCE WITH INSTRUCTIONS FROM MANUFACTURER OF THE SYSTEM. REFER TO APPROVED SHOP DRAWINGS FOR EXACT OUTLET BOX SIZES, LOCATION AND FEEDER REQUIREMENTS.

LIGHT FIXTURES

- A RECESSED 2' X 4' FLUORESCENT PARABOLIC, LITHONIA CAT. NO. 2PM3GB-3-40-18D-120ES, WITH THREE (3) F40T12CW LAMPS. PROVIDE ENERGY SAVING LAMPS AND BALLASTS.
- B RECESSED 2' X 4' FLUORESCENT TROFFER, LITHONIA CAT. NO. 2SPG-340-A12-120ES, WITH THREE (3) F40T12CW LAMPS. PROVIDE ENERGY SAVING LAMPS AND BALLASTS.
- C RECESSED INCANDESCENT DOWNLIGHT, LITHONIA CAT. NO. A6AR, WITH ONE (1) 150A21 LAMP.
- D RECESSED INCANDESCENT WALL WASH DOWNLIGHT, LITHONIA CAT. NO. AW6AR WITH ONE (1) 150A21 LAMP.
- E SURFACE MOUNTED FLUORESCENT WRAPAROUND, LITHONIA CAT. NO. VC240-120ES WITH TWO (2) F40T12CW LAMPS. PROVIDE ENERGY SAVING LAMPS AND BALLASTS.
- G SURFACE MOUNTED FLUORESCENT STRIP, LITHONIA CAT. NO. S140-120ES, WITH ONE (1) F40T12CW LAMP.
- H SURFACE MOUNTED FLUORESCENT WALL BRACKET, LITHONIA CAT. NO. WS-240A12-120ES WITH TWO (2) F40T12CW LAMPS. PROVIDE BODINE BATTERY INVERTOR B-30.
- J RECESSED INCANDESCENT, LITHONIA CAT. NO. LG7RWFFL WITH ONE (1) 150A21 LAMP.
- K SURFACE MOUNTED H.I.D. WALL-PACK, LITHONIA CAT. NO. TWP175M-120, WITH ONE (1) 175 WATT METAL HALIDE LAMP.
- L SAME AS FIXTURE TYPE "A" EXCEPT TO HAVE BODINE BATTERY INVERTER B-30.
- M SAME AS FIXTURE TYPE "B" EXCEPT TO HAVE BODINE BATTERY INVERTER B-30.
- N SAME AS FIXTURE TYPE "GG" EXCEPT TO HAVE BODINE BATTERY INVERTER B-30.
- P SAME AS FIXTURE TYPE "G" EXCEPT TO BE 3' LONG.
- Q ALCO DIRECTIONAL INCANDESCENT, CAT. NO. 107, LAMPS INCLUDED WITH FIXTURE.
- R RECESSED H.I.D., LITHONIA CAT. NO. LAH250M-12SBT73 WITH ONE (1) 175 WALL METAL HALIDE LAMP.
- T RECESSED H.I.D. DOWNLIGHT, LITHONIA CAT. NO. LGH175M-12SB-FFL-120V WITH ONE (1) 175 WATT METAL HALIDE LAMP.
- U PENDANT MOUNTED CHANDELIER, TO BE FURNISHED BY OWNER AND INSTALLED BY ELECTRICAL CONTRACTOR.
- V SURFACE MOUNTED FLUORESCENT, PROGRESS CAT. NO. P7149-10, WITH TWO (2) F40T12CW LAMPS.
- W SURFACE MOUNTED INCANDESCENT PIT LIGHT, HUBBELL CAT. NO. VWX-151, WITH ONE (1) 150W21 LAMP. PROVIDE VCG-15 WIRE GUARD.
- X SAME AS FIXTURE TYPE "G" EXCEPT TO BE 2'0" LONG.
- Y SAME AS FIXTURE TYPE "C" EXCEPT TO HAVE BODINE BATTERY INVERTER.
- Z POLE MTD. H.I.D., HADCO CAT. NO. VH60A18/PC/Q/F, WITH ONE (1) 250 WATT METAL HALIDE LAMP. PROVIDE HADCO POLE P-1790-14
- AA GROUND MOUNTED H.I.D. FLOODLIGHT, KIM CAT. NO. AFL1-175MH120-BLP, WITH ONE (1) 175 WATT METAL HALIDE LAMP.
- BB FLUORESCENT SKYLIGHT, 4'X4' PRUDENTIAL CAT. NO. P-8748-48RS-FWA WITH SIX (6) F40T12CW LAMPS.
- CC SURFACE MOUNTED FLUORESCENT, FORM CAT. NO. BAE-2020X2/2 (WALNUT) WITH TWO (2) F20T12W LAMPS.
- DD SURFACE MOUNTED INCANDESCENT, BRYANT CAT. NO. 522B WITH ONE 150A19 LAMP.
- EE RECESSED H.I.D. DOWNLIGHT, LITHONIA CAT. NO. AH70M7AR, WITH ONE (1) 70 WATT METAL HALIDE LAMP.
- FF RECESSED H.I.D. WALL-WASH, LITHONIA CAT. NO. AHW70M7AR, WITH ONE (1) 70 WATT METAL HALIDE LAMP.
- GG CHAIN MOUNTED 4' INDUSTRIAL FLUORESCENT, LITHONIA CAT. NO. AF240-120ES, WITH TWO (2) F40T12CW LAMPS. Note : Light Fixture Type GG/By Owner
- HH GROUND MOUNTED H.I.D. FLOODLIGHT, KIM CAT. NO. AFL7-250MH120-BLP, WITH ONE (1) 250 WATT METAL HALIDE LAMP.
- JJ RECESSED LOW VOLTAGE WALLWASH, LITHONIA CAT. NO. DVM4AC WITH ONE (1) 50WMR1610/FL (EXN) LAMP.
- KK RECESSED H.I.D. DOWNLIGHT, LITHONIA CAT. NO. LGH100M9SBFFL-120, WITH ONE (1) 100 WATT METAL HALIDE LAMP.
- LL RECESSED H.I.D. WALL WASH, LITHONIA CAT. NO. DHW175ASL-120 WITH ONE (1) 175R40 METAL HALIDE LAMP.

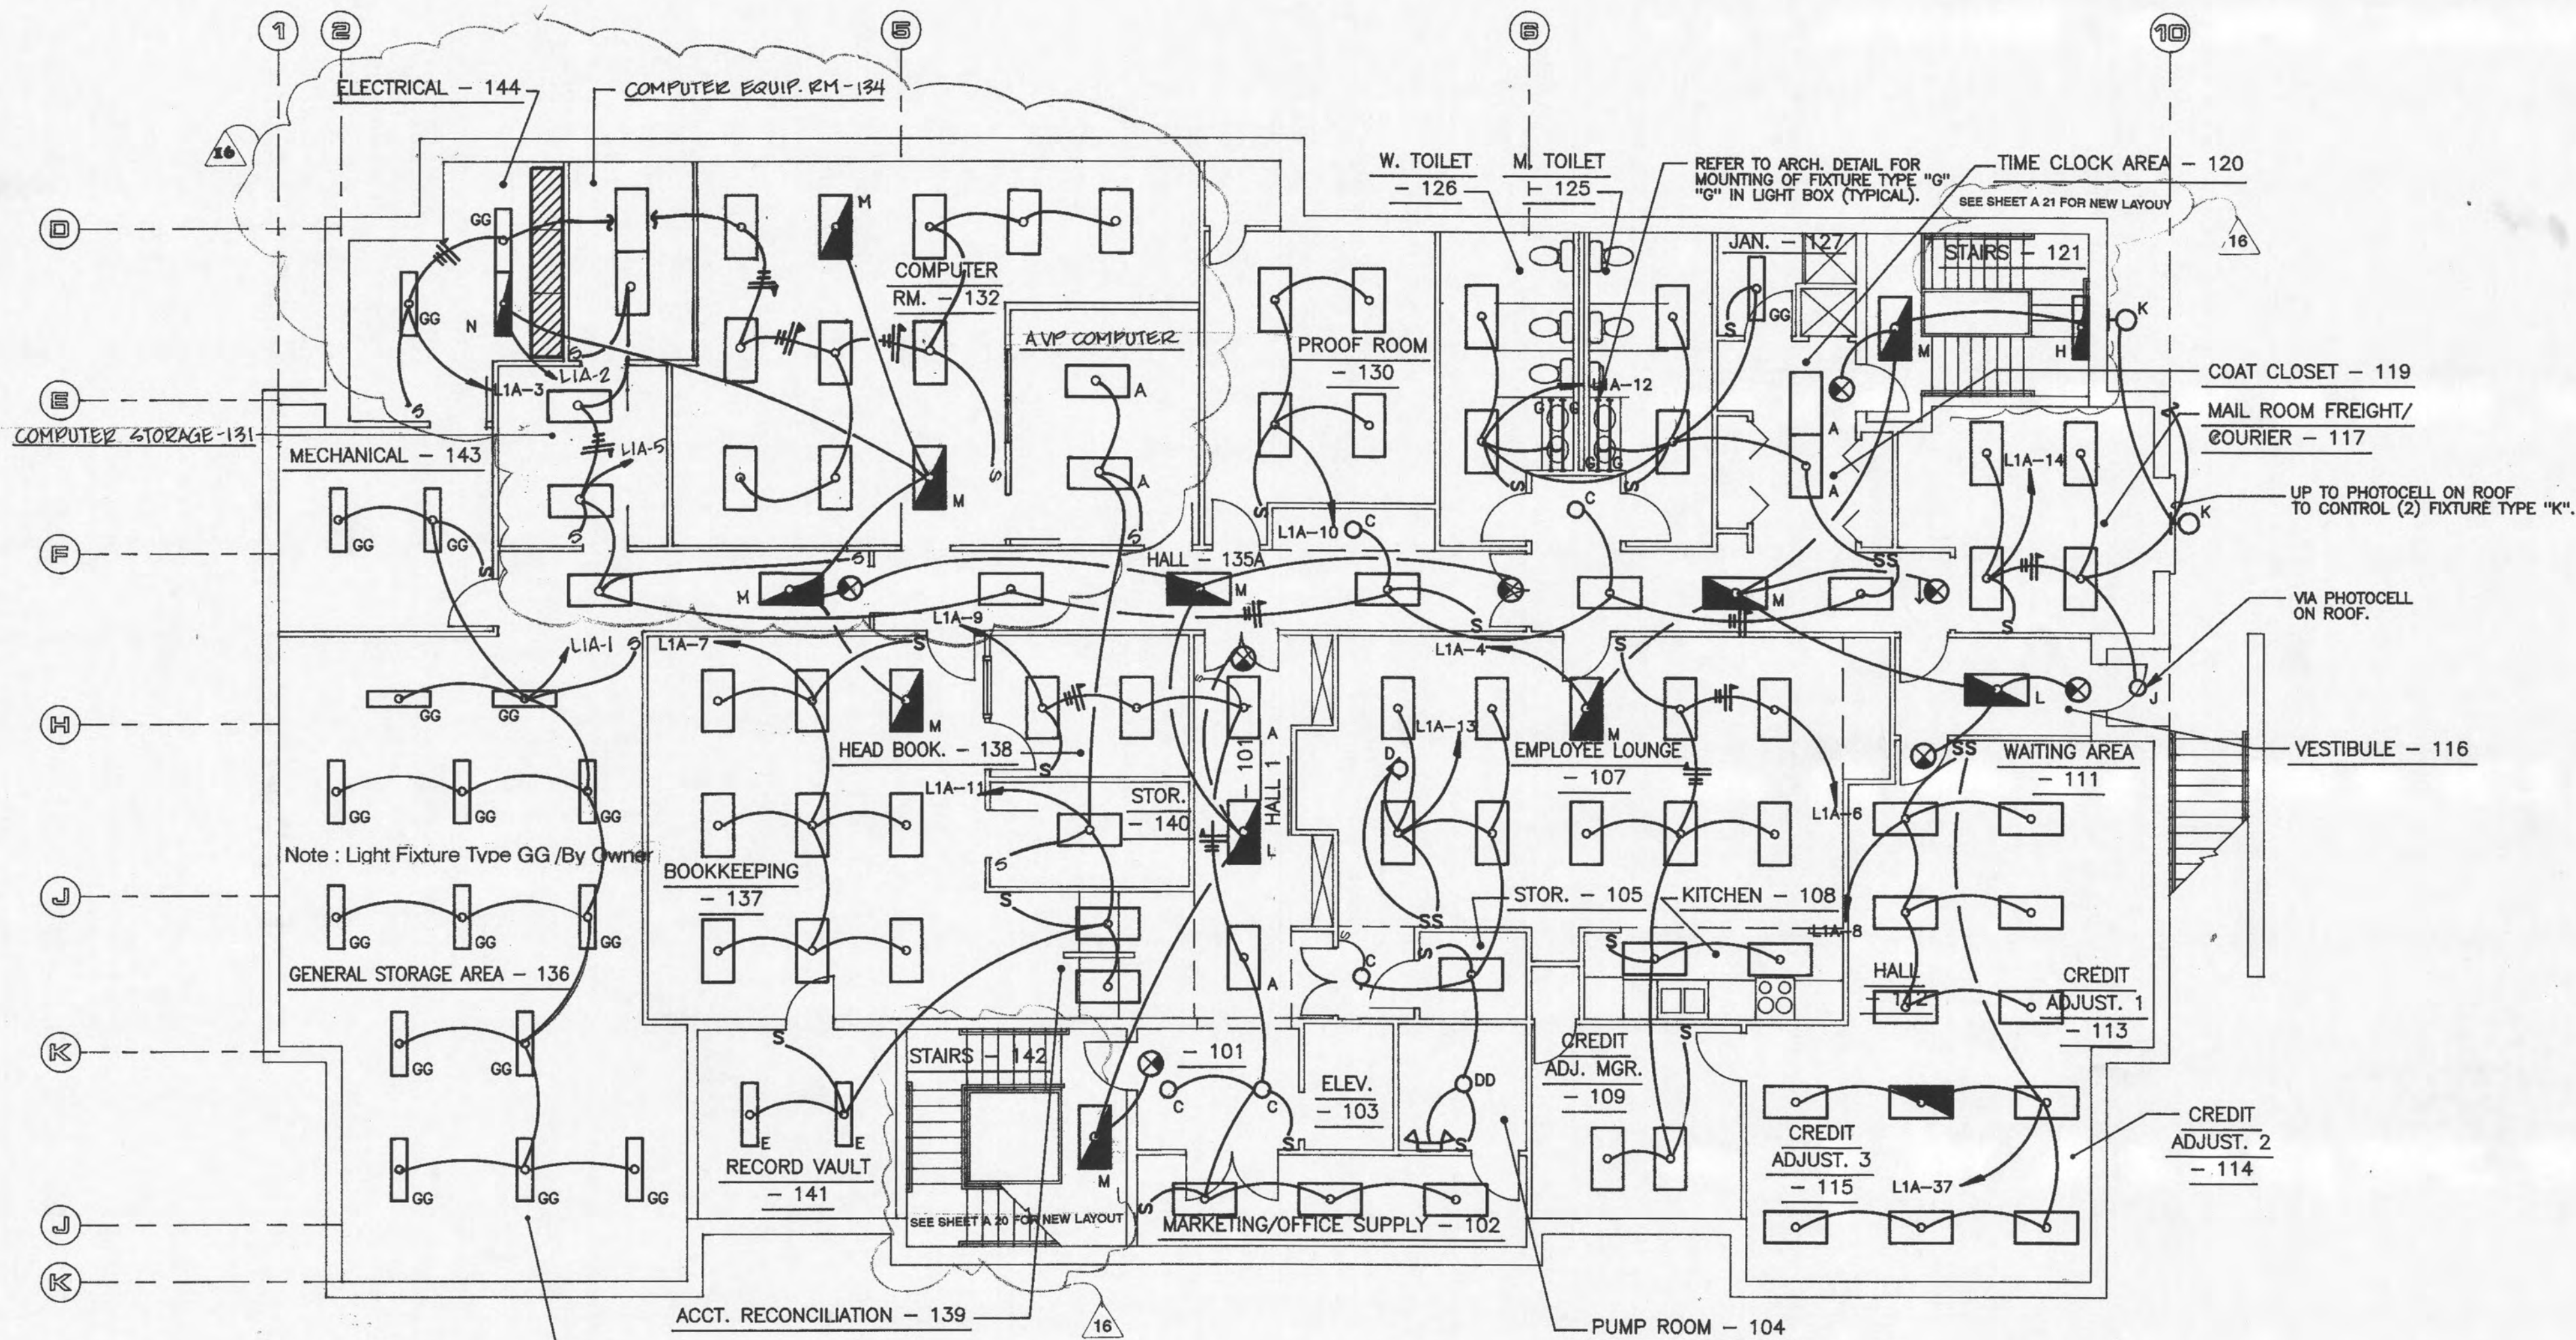





NOTE: ALL LIGHT FIXTURES SHALL BE TYPE "A" UNLESS NOTED OTHERWISE.

- 1 REFER TO ARCHITECTURAL DETAIL FOR LOCATION OF FIXTURE IN LIGHT BOX
- 2 SPECIAL SWITCH ARRANGEMENT AND COVERPLATE. SEE DETAIL ON THIS SHEET
- 3 TO PHOTOCELL ON TOP OF CANOPY TO CONTROL DRIVE-THRU CANOPY LIGHTS
- 4 OPEN-CLOSED TRAFFIC LIGHT. SEE ARCHITECTURAL PLANS FOR EXACT LOCATION. SEE THIS SHEET FOR SWITCHING DETAIL
- 5 CONNECT TO LIGHT IN DEPOSITORY HEAD
- 6 CIRCUIT TO BE CONTROLLED BY BREAKER IN PANELBOARD
- 7 FIXTURES OUTSIDE ATM TO BE CONTROLLED VIA PHOTOCELL ON ROOF
- 8 REFER TO ARCHITECTURAL DETAIL FOR EXACT MOUNTING OF FIXTURE "CC"



DATE 9-9-92

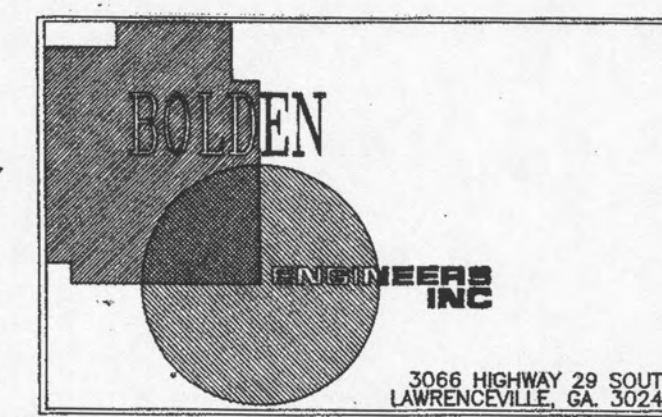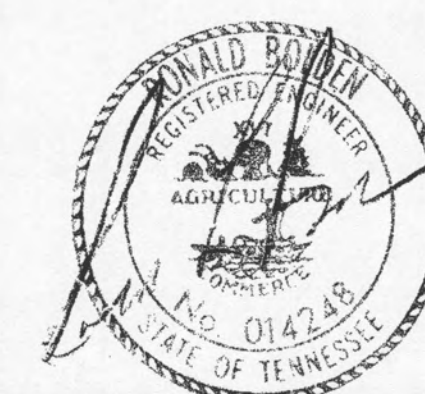





- 1 REFER TO ARCHITECTURAL DETAIL FOR LOCATION OF FIXTURE IN LIGHT BOX.
- 2 CIRCUIT TO BE CONTROLLED BY BREAKER IN PANEL.
- 3 CIRCUIT TO BE CONTROLLED BY PHOTO-CELL ON ROOF.



NOTE: ALL LIGHT FIXTURES SHALL BE TYPE "B" UNLESS NOTED OTHERWISE

DATE 9-9-92

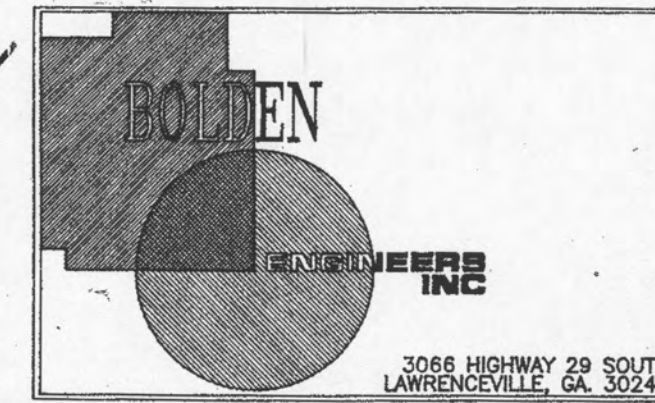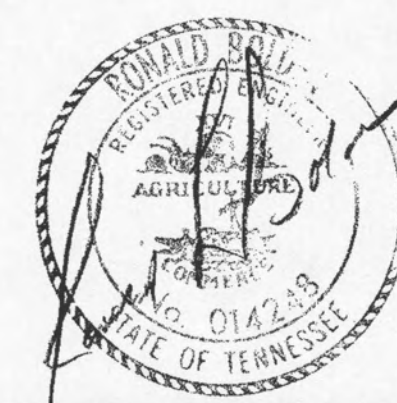

SERVICE	WATTS	CKT NO.	ABC	CKT NO.	WATTS	SERVICE
LIGHTING - GENERAL STORAGE	1,300	1		2	1,200	LIGHTING - NIGHT LIGHTS *
- ELEC. - COMP. RM.	1,550	3		4	850	- NIGHT LIGHTS *
- VP COMP. CORRIDOR	1,350	5		6	1,350	- LOUNGE, CREDIT
- BOOKKEEPING	1,200	7		8	1,500	- CREDIT
- HALL STOR. BOOKKEEPER	1,350	9		10	900	- PROOF
- COMP STOR. RECORDS	1,200	11		12	1,200	- RESTROOMS, JAN. CORT
- TRAINING, STOR.	1,200	13		14	900	- MAIL, OUTSIDE
- SIGN	1,000	15		16	1,500	- FLOODLIGHTS (VIA PHOTO-CELL)
- SIGN	1,000	17		18	2,700	- PARKING LIGHTS (VIA PHOTO-CELL)
RECEPTACLES - COPIER	1,200	19		20		
- PROOF	540	21		22	1,010	BOOKLIFT (1/2 HP)
- PROOF	540	23		24		
- E.D.F.	750	25		26	330	ELEVATOR PIT LIGHT AND RECEPTAL
- R.R., E.D.F.	300	27		28	300	RECEPTACLE - PUMP
- R.R., JAN.	600	29		30	300	HVAC CONTROLS
- E.D.F.	750	31		32	1,000	RECEPTACLES - VENDINGS
- COMPUTER ROOM	300	33		34	1,000	"
LIGHTING - OUTSIDE (VIA PHOTO CELL)	600	35		36	1,000	"
RECEPTACLES-OUTDOOR GEN.BAT.	180	37		38		SPARE
SPARE		39		40		
"		41		42	300	FIRE ALARM *



PANEL SCHEDULE "L1A"		CONNECTED LOAD	* - INDICATES LOCK-ON DEVICES.
SERVICE	120/208V - 3PH - 4W	33.0 KVA	⊕ - INDICATES "GFI" BREAKER.
MAINS	225 AMP M.L.O.		— PROVIDE SEPARATE GROUND BUS
BRANCHES	20/1 EXCEPT AS NOTED		
PANEL MOUNTING	RECESSED		

SERVICE	WATTS	CKT NO.	ABC	CKT NO.	WATTS	SERVICE
RECEPTACLES - ELEC. RM.	360	1		2	360	RECEPTACLES - BOOKKEEPING (L.G.)
- TELEPHONE	300	3		4	360	"
- MECH RM/HALL	360	5		6	360	"
- STOR/BOOKKEEPING	540	7		8	540	- BKPL/PROOF RM.(L.G.)
- BOOKKEEPING	540	9		10	540	"
- STOR/HALL	720	11		12	180	- CREDIT MGR. (L.G.)
- TRAIN/LOUNGE	720	13		14	360	- CREDIT ADJ. (L.G.)
- CREDIT ADJUST.	1,000	15		16	180	"
- MAIL	1,000	17		18	8,300	RANGE
- CREDIT ADJUST.	540	19		20		
- CREDIT ADJUST.	540	21		22	1,200	DISHWASHER
- BOOKKEEPING	540	23		24	1,200	REFRIGERATOR
DISPLAY-SHELVING	1,000	25		26	1,000	RECEPTACLES - KITCHEN
TELEVISION	1,000	27		28	1,000	"
EMH-1	1,000	29		30	1,000	"
EMH-2	1,000	31		32	360	- PUMP ROOM
SPARE	1,000	33		34	600	- ELEVATOR LIGHTS AND FAN
"	1,000	35		36	600	SUMP PUMP
"	1,000	37		38	540	RECEPTACLES - STORAGE
"	1,000	39		40		SPARE
"	1,000	41		42		"

PANEL SCHEDULE "P1A"		CONNECTED LOAD	* - INDICATES LOCK-ON DEVICES.
SERVICE	120/208V - 3PH - 4W	36.9 KVA	⊕ - INDICATES "GFI" BREAKER.
MAINS	225 AMP M.L.O.		— PROVIDE SEPARATE GROUND BUS
BRANCHES	20/1 EXCEPT AS NOTED		— PROVIDE ISOLATED GROUND BUS
PANEL MOUNTING	RECESSED		

NOTES (THIS SHEET ONLY)

- JUNCTION BOX FOR SUMP PUMP.
- LOCATE SWITCH, PIT LIGHT AND RECEPTACLE AS DIRECTED BY ELEVATOR SUPPLIER.
- RUN (2) 2" DIA. SLEEVES FOR ELEVATOR CONTROLS BETWEEN ELEVATOR AND PUMP ROOM.
- ELEVATOR CONTROLS BY OTHERS.
- PROVIDE 30A 2 POLE H.D. DISC. SWITCH WITH ONE (1) 20 AMP FUSE FOR ELEVATOR FAN AND LIGHTS. LOCATE AS DIRECTED BY ELEVATOR CONTRACTOR.
- CO-ORDINATE REQUIREMENTS AND EXACT LOCATION OF ELEVATOR EQUIPMENT WITH ELEVATOR SUPPLIER PRIOR TO ROUGH-IN.
- (2) 4" X 8" X 3/4" PLYWOOD TELEPHONE BACKBOARD. RUN #6 GROUND WIRE FROM MAIN BUILDING GROUND TO TELEPHONE BACKBOARD AND 8" OF SLACK WIRE AT THE BACKBOARD.
- CONNECT TO DUMBWATER CONTROL PANEL AND CONNECT TO 1/2 H.P. SINGLE PHASE, 208 VOLT MOTOR IN LIFT SHAFT. SEE MANUFACTURERS SHOP DRAWINGS FOR EXACT REQUIREMENTS. ALL WORK TO BE IN STRICT COMPLIANCE WITH INSTRUCTIONS FROM MANUFACTURER OF DUMBWATER.
- TO MAIN DISTRIBUTION PANEL "MDP" - 150/3 IN ELECTRICAL ROOM.
- MAKE CONNECTION TO DISPLAY UNIT AS REQUIRED.
- PROVIDE RELAYS AND CONTACTS TO SHUT-DOWN HPIU-1 WHEN SMOKE IS DETECTED IN DUCT DETECTOR. FIRE ALARM IS ACTIVATED FROM ANY LOCATION, OR WHEN E.P.O. BUTTON IS PRESSED. COMPUTER ROOM HVAC UNIT (HPIU-1) IS TO BE SHUT DOWN WHENEVER ANY OF THESE EVENTS OCCUR.
- 4" SQUARE X 2-1/8" DEEP FLUSH MOUNTED JUNCTION BOX. 9-1/2" DOWN FROM FINISHED CEILING LINE OR 8" 7-3/4" A.F.F. MAX. FOR CCTV CAMERA. LOCATE A DUPLEX RECEPTACLE IN WALL JUST ABOVE CEILING FOR CCTV CAMERA TRANSFORMER TO PLUG INTO.
- PROVIDE DOUBLE CONTACT ON EPO BUTTON. ONE SET TO SHUNT TRIP MAIN BREAKER IN PNL "CP"; OTHER SET TO SHUT OFF HPIU-1 (SEE NOTE 11).
- PROVIDE ONE 120V RECEPTACLE IN CEILING SPACE FOR CAMERA CONNECTION.
- CIRCUITS FOR ISOLATED GROUND RECEPTACLES SHALL CONTAIN GREEN EQUIPMENT GROUND AND ISOLATED GROUND SHALL BE GREEN WITH WHITE TRACER.
- ALL RECEPTACLE ABOVE COUNTERS SHALL BE MOUNTED HORIZONTALLY. SEE DETAIL ON SHEET E-8.

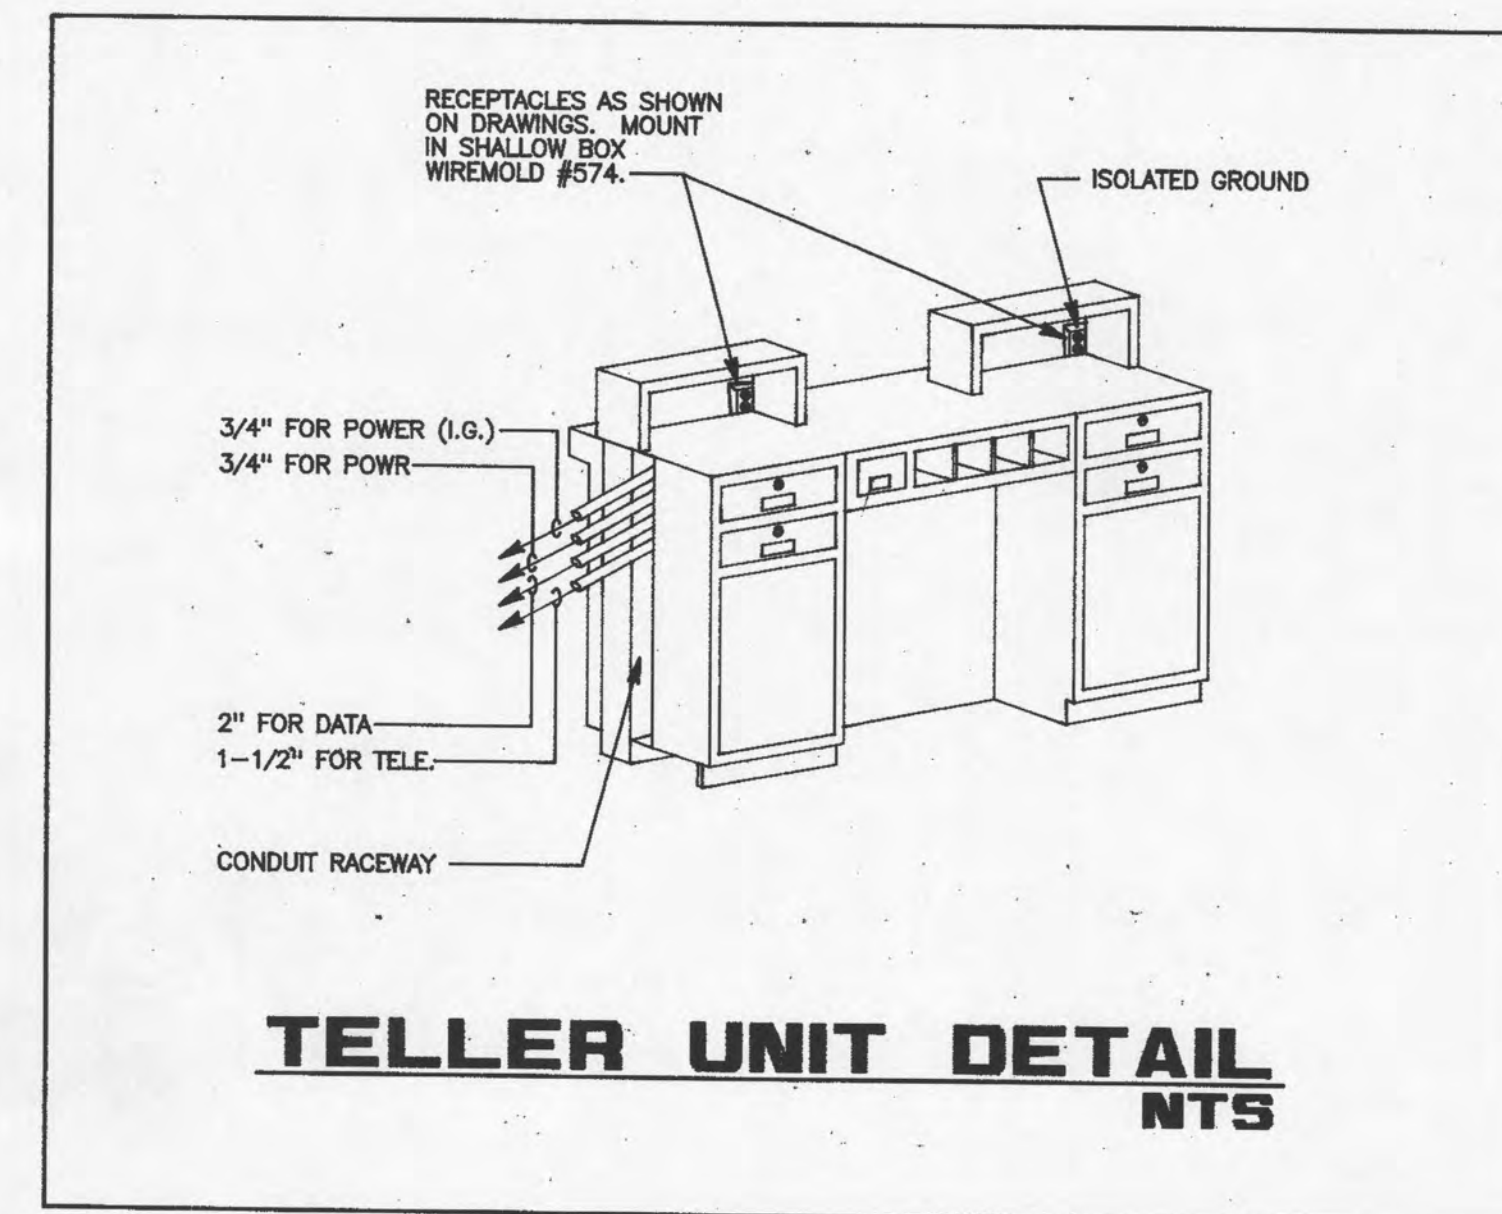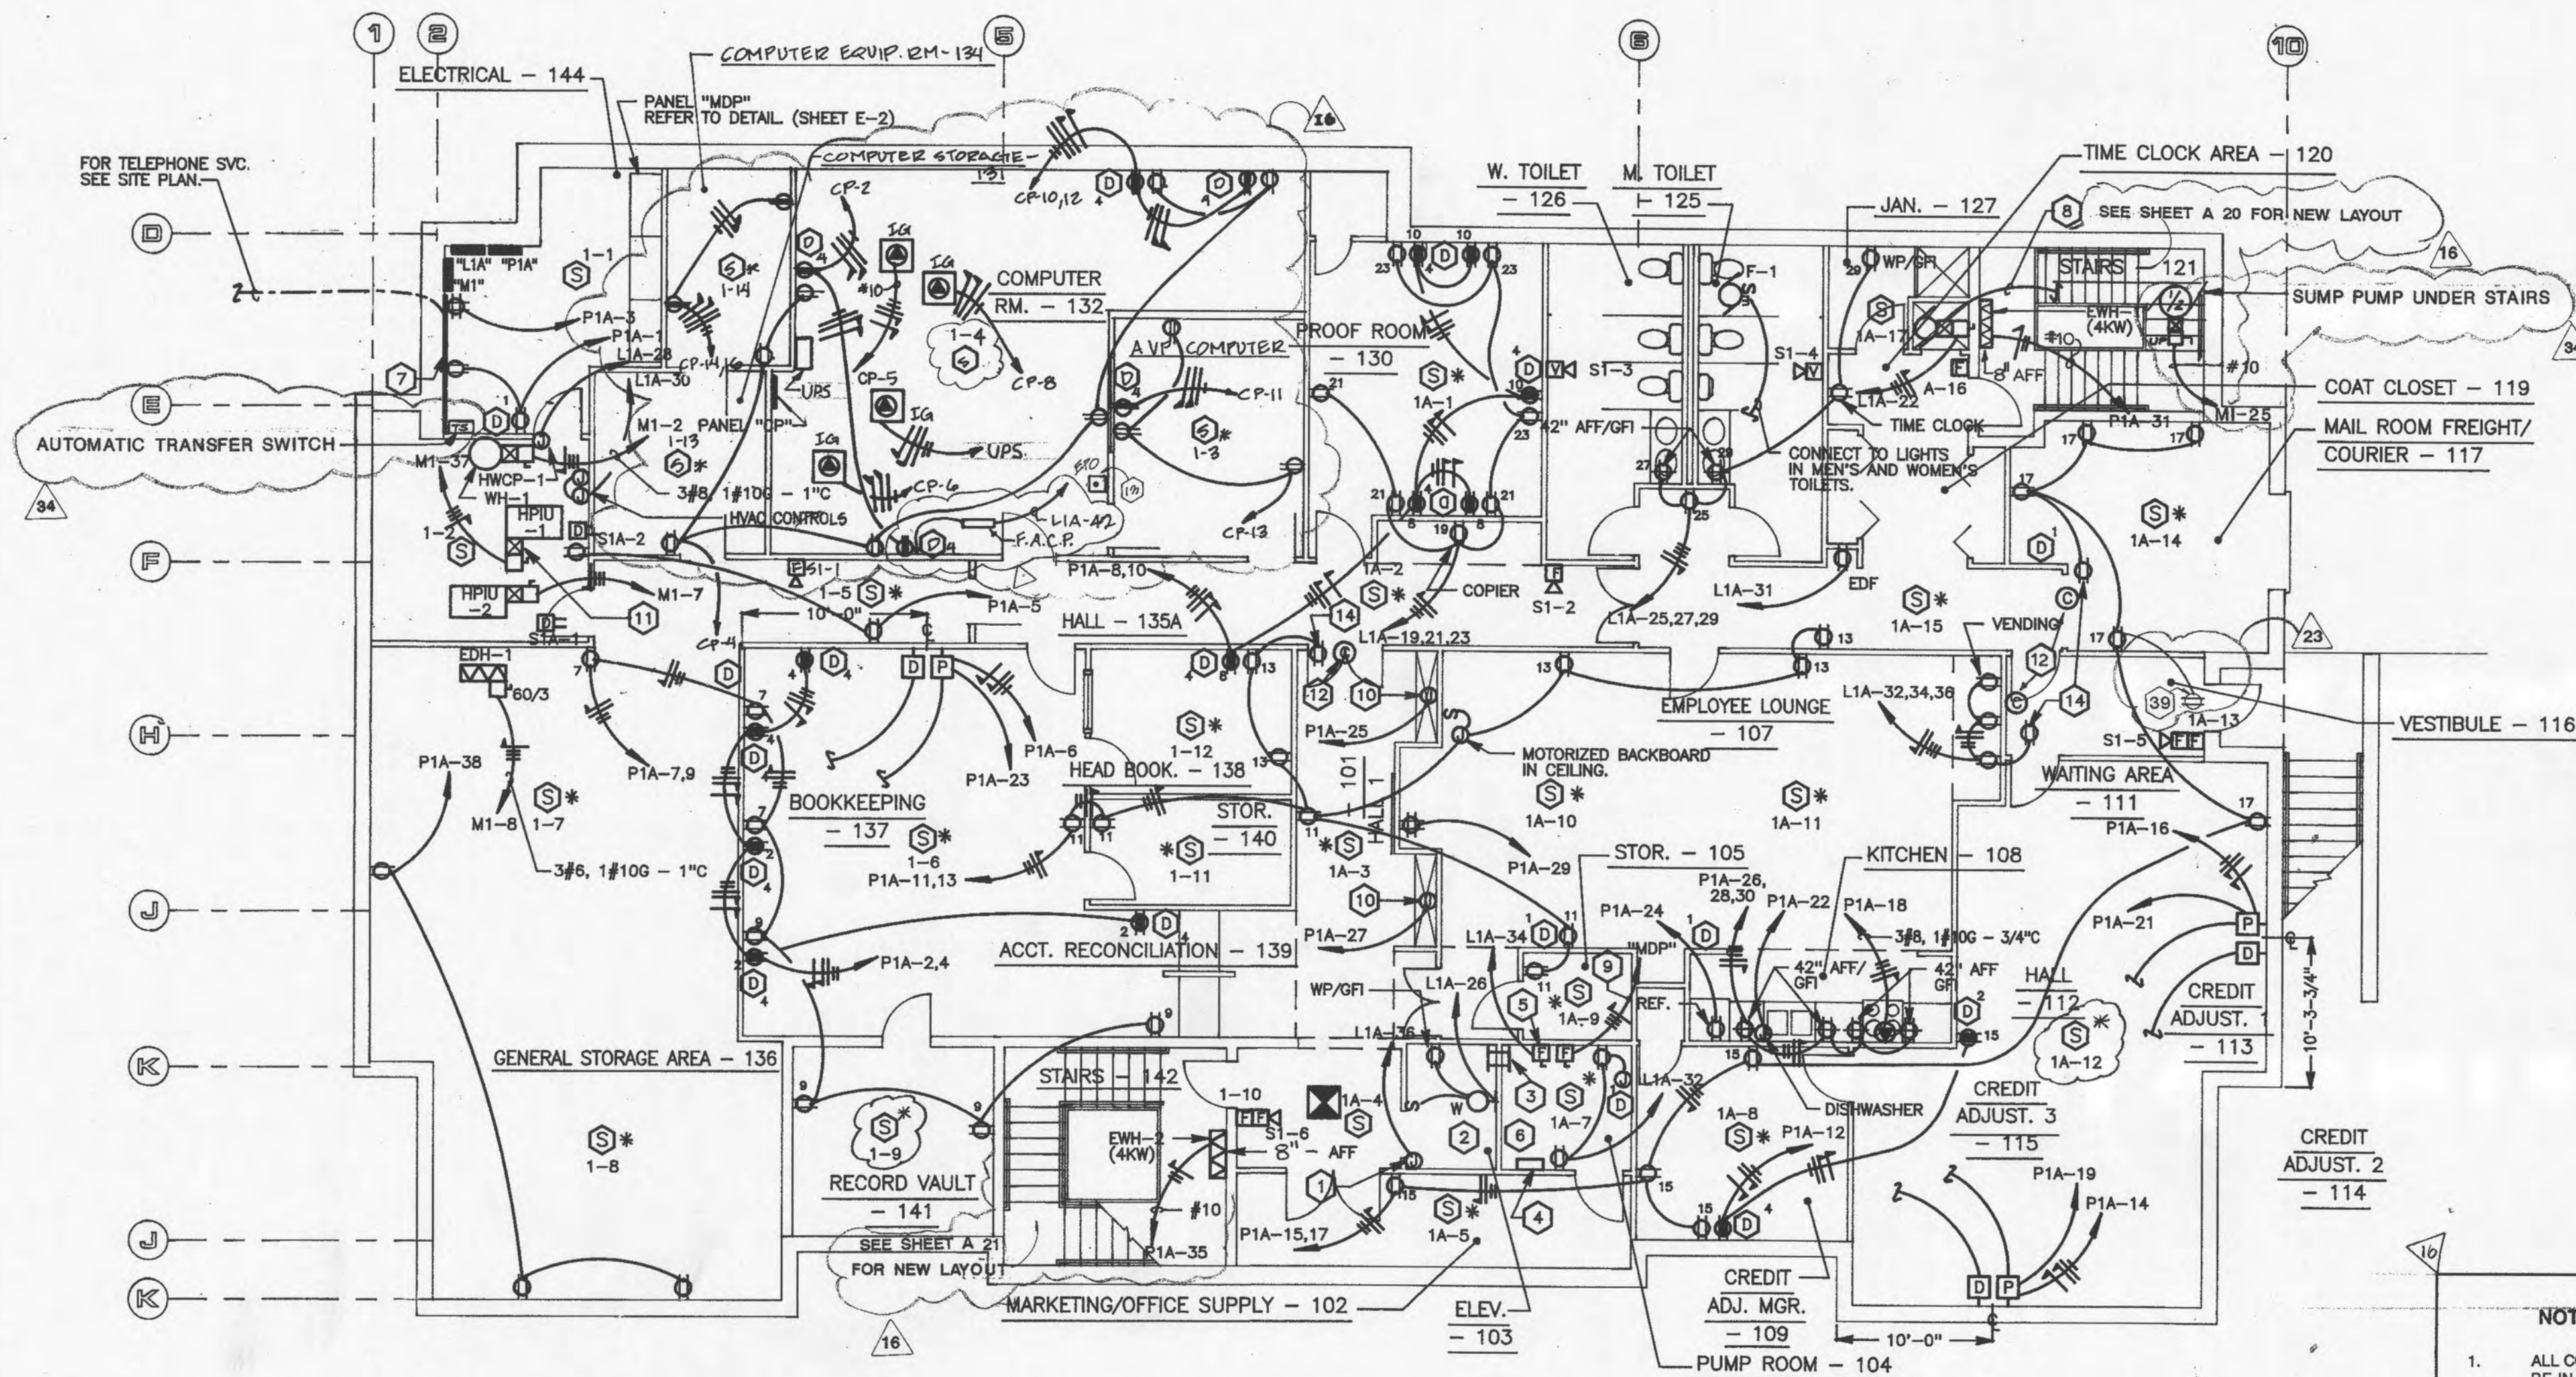


NOTES (COMPUTER ROOM-132)

- ALL CONDUIT RUN UNDER RAISED FLOOR SHALL BE IN LIQUID TIGHT FLEXIBLE METAL CONDUIT.
- UPS TO BE FURNISHED BY OWNER.
- CO-ORDINATE EXACT LOCATION AND ELECTRICAL REQUIREMENTS OF ALL EQUIPMENT IN COMPUTER ROOM WITH BOB KING AT THE BANK OF ROANE COUNTY.
- CO-ORDINATE ALL EQUIPMENT THAT IS TO BE RUN OFF THE U.P.S. WITH OWNER.
- ALL EQUIPMENT CONNECTED TO THE UPS SHALL BE CONNECTED VIA RECEPTACLE IN BACK OF U.P.S. COORDINATE PLUG AND RECEPTACLE TYPE OF EQUIPMENT AND U.P.S.



DATE 9-9-92

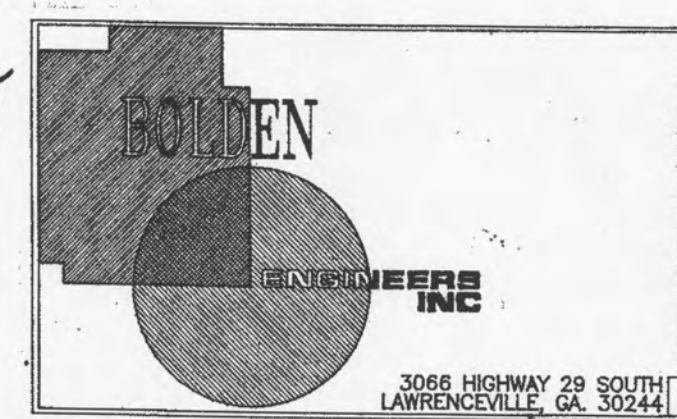

343	DATE	BY	CHECKED BY
343	September 9, 92	16	
	October 1992	23	
	December 31, 92	34	

- Consultants
- Designers
- Construction Managers

design-build
design-build
design-build
Concepts
SVP: David Reid

RELEASED FOR CONSTRUCTION

ELECTRICAL FLOOR PLAN / POWER - LEVEL 1

A NEW MAIN OFFICE FACILITIES FOR:

Bank of Roane County
HARRISMAN, TENNESSEE

DATE: JUNE 19, 1992

E-6

LEVEL 1 **ROOM FINISH SCHEDULE**

ROOM NO.	ROOM NAME	FLR.	BASE	WALLS	CLG.	CLG. HT.	FINISH
101	HALL #1	1	C	1	8/2	8'-0"	
102	MKTG/OFFICE SUPPLY	1	A	1	8/2	8'-0"	
103	ELEVATOR	1	A	1	8/2	8'-0"	Fin. by Elec. Mkt.
104	PUMP ROOM	1	A	1	8/2	8'-0"	
105	STORAGE	1	A	1	8/2	8'-0"	
106	TRAINING ROOM	1	A	1	8/2	8'-0"	
107	EMPLOYEE LOUNGE	1	A	1	8/2	8'-0"	
108	KITCHEN	1	A	1	8/2	8'-0"	
109	CREDIT ADJ. MGR	1	A	1	8/2	8'-0"	
110	CLOSET	1	A	1	8/2	8'-0"	
111	WAITING	1	A	1	8/2	8'-0"	
112	HALL	1	A	1	8/2	8'-0"	
113	CREDIT ADJUST. #1	1	A	1	8/2	8'-0"	
114	CREDIT ADJUST. #2	1	A	1	8/2	8'-0"	
115	CREDIT ADJUST. #3	1	A	1	8/2	8'-0"	
116	VESTIBULE	1	A	1	8/2	8'-0"	
117	MAIL ROOM	1	A	1	8/2	8'-0"	
118	TIME CLOCK AREA	1	A	1	8/2	8'-0"	
119	COAT CLOSET	1	A	1	8/2	8'-0"	
120	BOOKLIFT	1	A	1	8/2	8'-0"	
121	STAR	1	A	1	8/2	8'-0"	
122	STORAGE CLOSET	1	A	1	8/2	8'-0"	
123	MEN'S TOILET	1	A	1	8/2	8'-0"	
124	WOMEN'S TOILET	1	A	1	8/2	8'-0"	
125	JANITOR	1	A	1	8/2	8'-0"	
126	COPPER	1	A	1	8/2	8'-0"	
127	PROOF	1	A	1	8/2	8'-0"	
128	COMPUTER STORAGE	1	A	1	8/2	8'-0"	
129	COMPUTER ROOM	1	A	1	8/2	8'-0"	
130	AVP COMPUTER	1	A	1	8/2	8'-0"	
131	COMPUTER EQUIP. ROOM	1	A	1	8/2	8'-0"	
132	HALL #2	1	A	1	8/2	8'-0"	
133	HALL #3	1	A	1	8/2	8'-0"	
134	SEAL STORAGE AREA	1	A	1	8/2	8'-0"	
135	BOOKKEEPING DEPT	1	A	1	8/2	8'-0"	
136	HEAD BOOKKEEPER	1	A	1	8/2	8'-0"	
137	ACCT RECONCILIATION AREA	1	A	1	8/2	8'-0"	
138	STORAGE	1	A	1	8/2	8'-0"	
139	RECORD VAULT	1	A	1	8/2	8'-0"	
140	STAIRS	1	A	1	8/2	8'-0"	
141	MECHANICAL	1	A	1	8/2	8'-0"	
142	ELECTRICAL	1	A	1	8/2	8'-0"	

LEGEND

FLOOR	BASE	WALLS	CEILING
1. CARPET (BY LNC)	A. RUBBER	1. GYP/PLM BRD.	A. 24" x 24" x 3/4" TYPE 1
2. MARBLE	B. CERAMIC	2. EXP. CONCRETE	B. 24" x 24" x 3/4" TYPE 2
3. RESILIENT	C. WOOD	3. CONC. BLOCK	C. 24" x 24" x 3/4" TYPE 3
4. CERAMIC TILE	D. CERAMIC	4. GLASS	D. 24" x 24" x 3/4" TYPE 4
5. MAT	E. EXP. CONCRETE	H. EXP. STRUCTURE	E. 24" x 24" x 3/4" TYPE 5
6. EXP. CONCRETE			F. GYP/PLM BOARD
			G. EXP. CONCRETE


INTERIOR WALL TYPES

- 3/8" METAL STUD @ 16" O.C. WITH 1/2" GWB ON BOTH SIDES.
- 3/8" METAL STUD @ 16" O.C. WITH 1/2" GWB ON BOTH SIDES (1 HOUR FIRE-RATING).
- 3/8" METAL STUD @ 16" O.C. WITH 1/2" GWB ON ONE SIDE.
- 3/8" METAL STUD @ 16" O.C. WITH 1/2" GWB ON ONE SIDE ONLY.
- 3/8" METAL STUD @ 16" O.C. WITH 1/2" GWB ON BOTH SIDES.
- 3/8" METAL STUD @ 16" O.C. WITH 1/2" GWB ON BOTH SIDES.
- 3/8" METAL STUD @ 16" O.C. WITH 1/2" GWB ON ONE SIDE ONLY.
- 3/8" METAL STUD @ 16" O.C. WITH 1/2" GWB ON ONE SIDE ONLY.
- 3/8" METAL STUD @ 16" O.C. WITH 1/2" GWB ON ONE SIDE ONLY.
- 3/8" METAL STUD @ 16" O.C. WITH 1/2" GWB ON ONE SIDE ONLY.

NOTE: ALL WALLS ARE TYPE 1 UNLESS OTHERWISE NOTED

NOTE: CORRIDOR WALLS ARE NOT RATED BASED ON FULLY SPRINKLERED BUILDING AND PROPOSED EQUIVALENT BASED ON NFPA 101 26-3.6, EXCEPTIONS No. 2, No. 3 AND 1991 EDITION SBC TABLE 700 & PL. 702.4.2

6 DETAIL **SCALE: N.T.S.** **TWO RAILS**

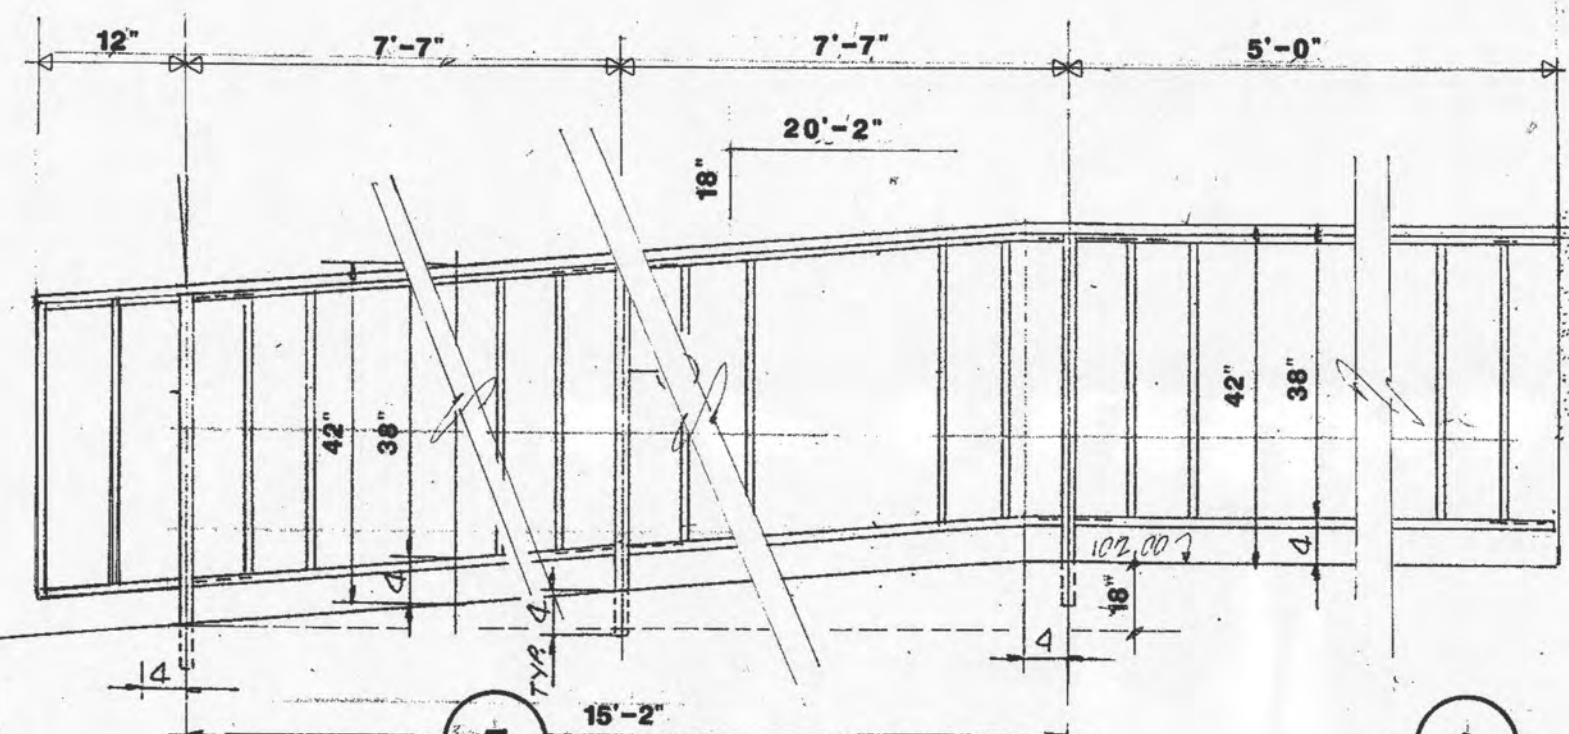

2 Partition Plan Detail **SCALE:**

(FIELD VERIFY)

1 2 3 5 6 8 9 10

4'-0" 10'-4" 25'-8" 40'-0" 25'-8" 10'-4" 4'-0"

56'-0" 51'-6"

1 2 3 5 6 8 9 10

4'-0" 10'-4" 25'-8" 40'-0" 25'-8" 10'-4" 4'-0"

56'-0" 51'-6"

- THE FOLLOWING SYSTEM TEST REPORT ACCORDING TO U.L. DIRECTORY FOR FIRE RESISTANCE MUST BE MET.
- | <u>TYPE</u> | <u>CONDUIT</u> | <u>SYSTEM NO.</u> |
|----------------|----------------|-------------------|
| CONCRETE SLAB | EMT | 49 |
| CONCRETE BLOCK | EMT | 49 |
| GYPSBOARD | EMT | 147 |

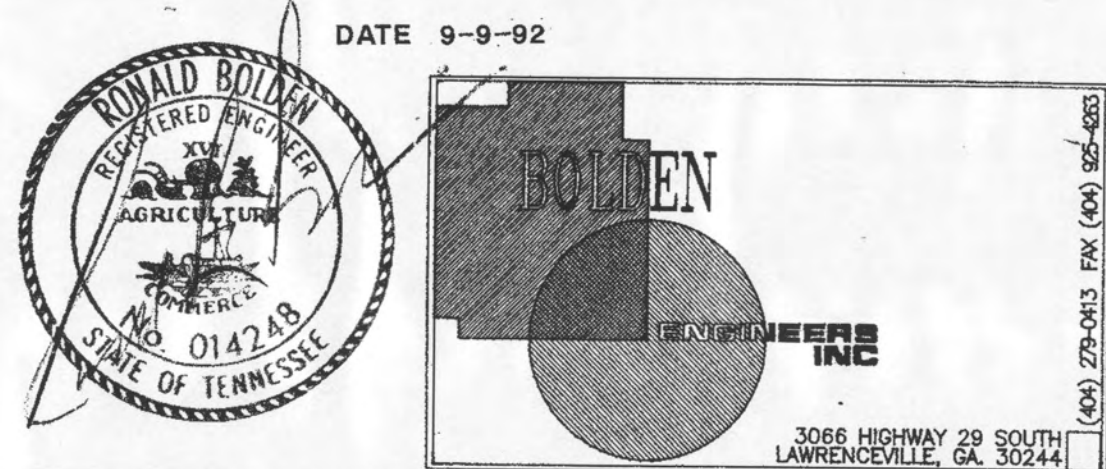

SERVICE		WATTS	CKT NO.	A B C	WATTS	CKT NO.	SERVICE
RECEPTACLES - SUPPORT V.P. OPR.	1,000	1		2	300	RECEPTACLES - SUPPORT (L.G.)	
- PRES. CED	1,000	3		4	300	- V.P./PRES. (L.G.)	
- BD. RM.	1,000	5		6	300	- HUMAN RESOURCES (L.G.)	
- GALLERY REF.	1,000	7		8	300	- MKTG. WORKROOM (L.G.)	
- GALLERY COFFEE	1,200	9		10	300	- CREDIT /VP ACCT. (L.G.)	
- "	1,200	11		12	510	- SYS.FURN. ACCT. (L.G.)	
- R.R. STOR.	360	13		14	300	- SYS.FURN. CREDIT (L.G.)	
- MKTG. WORKRM.	1,000	15		16	300	- " " "	
- V.P. ADMIN.	900	17		18	300	- " " "	
- HUMAN RES.	900	19		20	510	- CREDIT /LOAN /SYS.FURN.	
- CLOSET, HALL	1,000	21	22	300	- " " "		
- VP ACCT. RVP CREDIT	1,000	23	24	300	- " " "		
- HALL	300	25	26	300	- " " "		
- COFFEE	1,200	27	28	300	- ACCT. CREDIT		
- MEN'S TOILET	100	29	30	300	- ATTIC SPACE		
- EDF	750	31	32	300	- HVAC CTRLS. MECH. RM.		
- WOMEN'S TOILET	100	33	34	100	- STORAGE		
- COPIER	1,200	35	36				
		37	38				
SPACE		39	40				
"		41	42				
"							

PANEL SCHEDULE

SERVICE 120/208V - 3PH - 4W

MAINS 225 AMP M.L.O.

BRANCHES 20/1 EXCEPT AS NOTED

PANEL MOUNTING SURFACE

"P3A"

CONNECTED LOAD

22.2 KVA

✱ - INDICATES LOCK-ON DEVICES.

↓ - INDICATES "GFI" BREAKER.

— PROVIDE SEPARATE GROUND BUS

— PROVIDE ISOLATED GROUND BUS

SERVICE			WATTS	CKT NO.	15/2	A	B	C	35/3	CKT NO.	WATTS	SERVICE		
HPIU-1	▲		1,128	1						2		9,888	WH-1 (5KW)	
SPARE				3						4				
				5	15/3				58/3	6				
HPIU-2			2,268	7						8		16,888	EDH-1 (18KW)	
				9						10				
				11	15/3				78/3	12				
HPIU-3			2,128	13						14		18,888	EDH-2 (18KW)	
				15						16				
				17	15/3				28/3	18				
HPIU-4			2,128	19						20		1,888	EDH-3 (4KW)	
				21						22				
				23						24				
SUMP PUMP			1,200	25						26			SPRCE	
SPACE				27						28				
				29						30				
	↓			31						32			↓	
SPARE			33						34					
"			35						36					
"				37						38				"
"			39						40					
"			41						42					

PANEL SCHEDULE

SERVICE 120/208V - 3PH - 4W

MAINS 225A M.L.O.

BRANCHES 20/1 EXCEPT AS NOTED

PANEL MOUNTING SURFACE

'M1'

CONNECTED LOAD

54.6 KVA

※ - INDICATES LOCK-ON DEVICES.

⊕ - INDICATES "GFI" BREAKER.

— PROVIDE SEPARATE GROUND BUS

▲ - PROVIDE SHUNT TRIP BREAKER.

SERVICE		WATTS	CKT NO.	15/3	A	B	C	15/3	CKT NO.	WATTS	SERVICE
EDH-5 (12 KW)	{	12,000	1						2	2,268	HP1U-5
			3	●				4			
			5	●				6			
			7	●				8			
			9	●				10			
EDJ-4 (6 KW)	{	6,000	11						12	2,268	HP1U-6
			13	●				14			
			15	●				16			
			17	●				18			
			19	●				20			
SPACE			21						22		SPACE
"			23						24		
"			25						26		
"			27						28		
"			29						30		
↓											↓

PANEL SCHEDULE

"M2"

SERVICE 120/208V - 3PH - 4W

MAINS 100 AMPS M.L.O.

BRANCHES 20/1 EXCEPT AS NOTED

PANEL MOUNTED SURFACE

CONNECTED LOAD


22.5 KVA

* — INDICATES LOCK-ON DEVICES.


⊘ — INDICATES "GFI" BREAKER.


— PROVIDE SEPARATE GROUND BUS

SERVICE		WATTS	CKT NO.	BO/2	A	B	C	CKT NO.	WATTS	SERVICE	
UPS-(8 KVA) BY OTHERS	8,000	1	30/2					2	540	RECETRACHES - COMPUTER ROOM (L.G.)	
		3	30/3					4	540	- " " "	
		5						6	1,000	- PRINTER (L.G.)	
READER SORTER	5,000	7						8	1,000	- JOGGER (L.G.)	
		9						10	368	- COMPUTER ROOM (L.G.)	
RECEPTRACLE - V.P. COMP. (L.G.)	368	11						12	368	- " " "	
" - V.P. COMP.	540	13						14	1,000	- DECOLLATER	
		15						16	1,000	- BURSTER	
SPARE		17						18		SPARE	
"		19						20		"	
"		21						22		"	
"		23						24		"	
SPICE		25						26		SPICE	
"		27						28		"	
"		29						30		"	

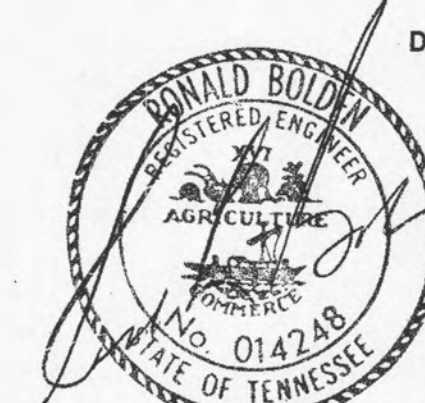



DATE 9-9-92

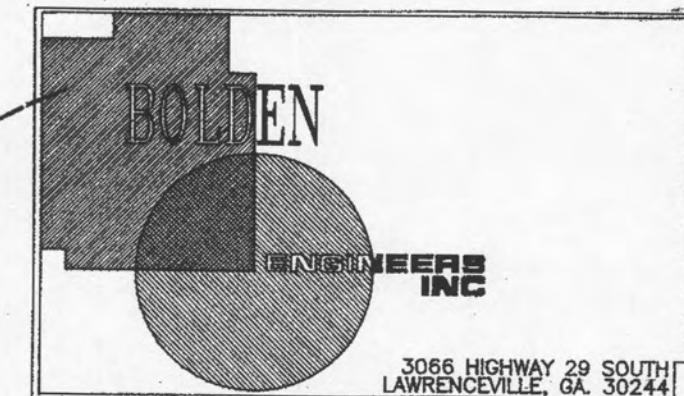

 

FLOOR	BASE	WALLS	CEILING
1. CARPET (BY L.W.C.)	A. RUBBER	1. GYPSUM BRD.	A. 24 x 24 x 3/4" TYPE 2
2. MARBLE	B. CERAMIC	2. EXP. CONCRETE	B. 24 x 24 x 3/4" TYPE 2
3. RESILIENT	C. WOOD	3. CONC. BLOCK	C. 24 x 24 x 3/4" TYPE 2
4. CERAMIC TILE		4. CONC. GLASS	D. 24 x 48 x 3/4" TYPE 5
5. MAT		E. 48 x 48 x 3/4" TYPE 5	F. GYPSUM BOARD
6. EXP. CONCRETE		G. EXP. CONCRETE	G. EXP. CONCRETE
7. FLOORING BY OWNER		H. EXP. STRUCTURE	H. EXP. STRUCTURE

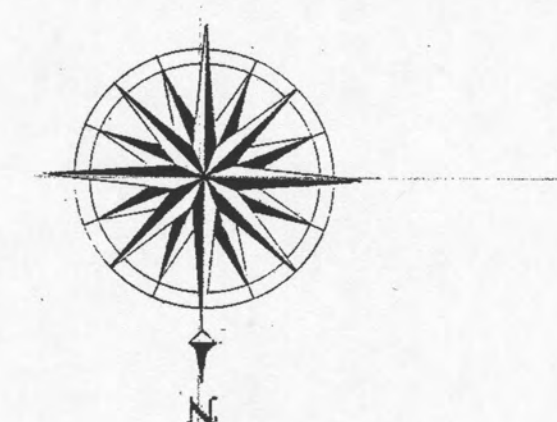

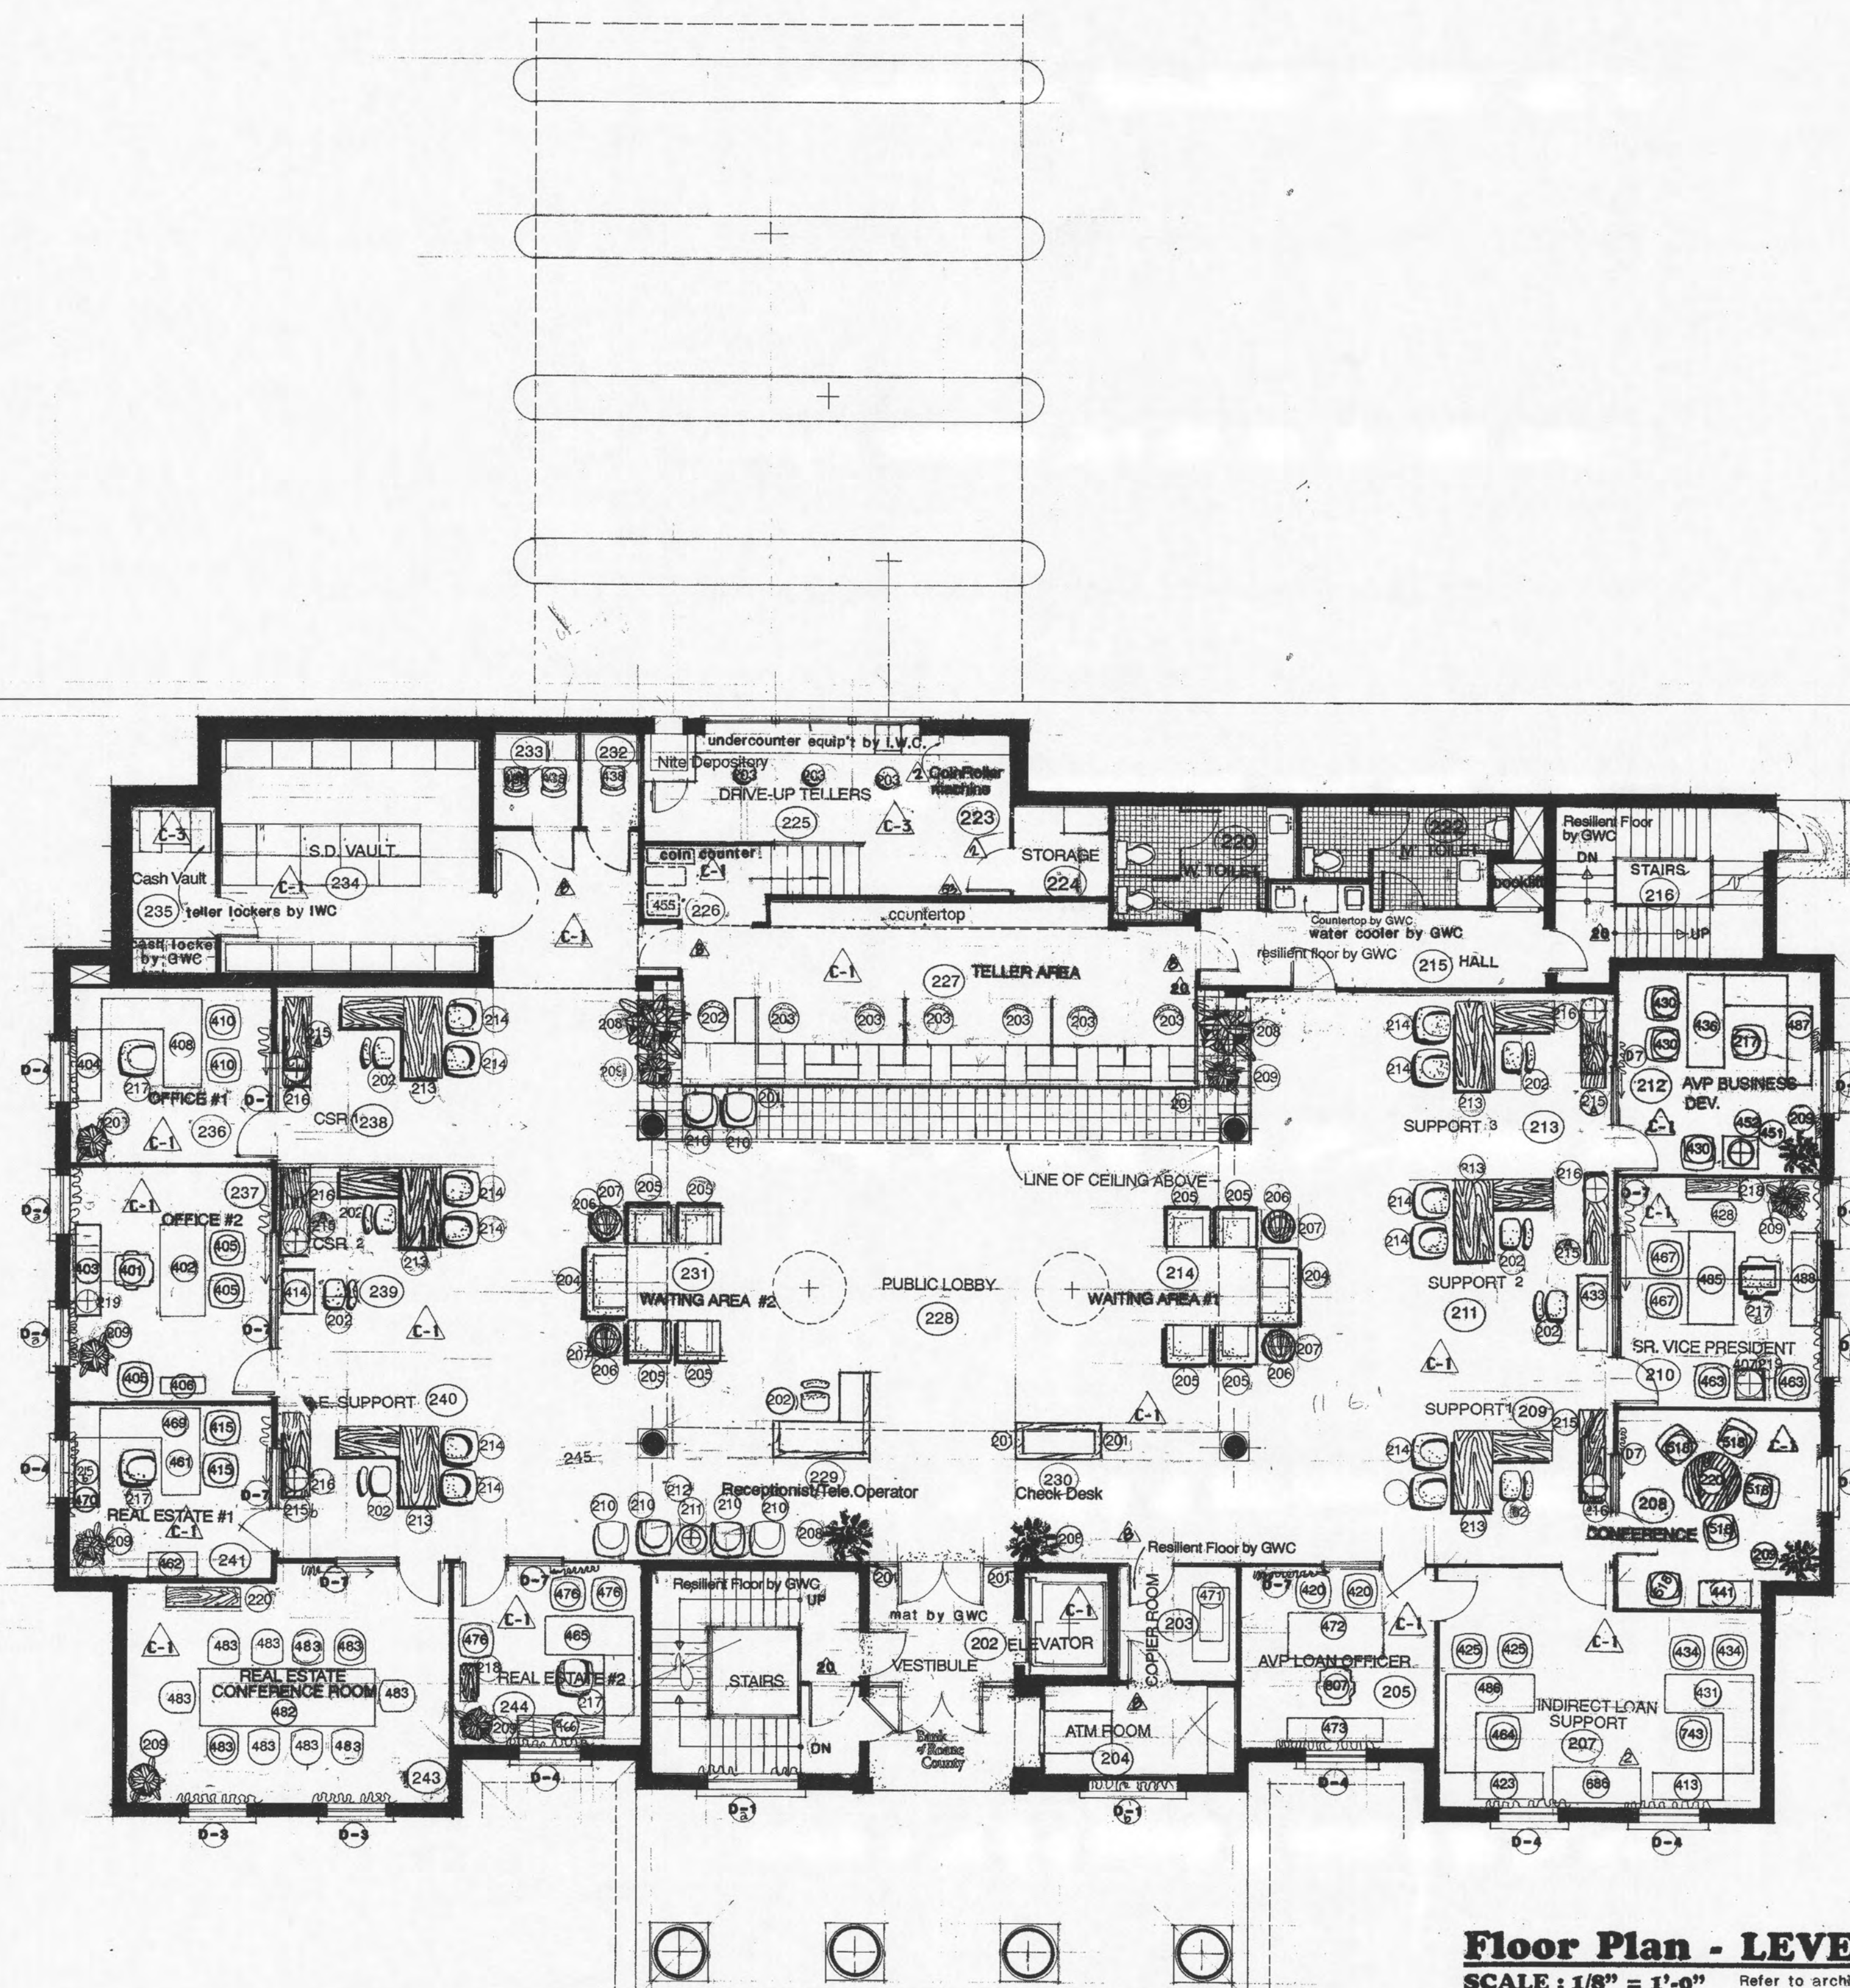

Floor Plan - LEVEL II

SCALE: 1/8" = 1'-0" Refer to architectural floor plans for dimensions

FLOOR PLAN LEGEND

- (D) 1,2 or 3 = New Furniture
- (D) New Furniture
- (D) 4,5,6,7,8 or 9 = Existing Furniture
- (D) Carpet
- (D) Drapery

Note: Interior plants by G.W.C. (part of landscaping)

ROOM FINISH SCHEDULE

ROOM NO.	ROOM NAME	FLR.	BASE	WALLS	CLG.	CLG. HT.	RMKS.
201	VESTIBULE	5	C	1	A/1	11'-6"	Refer to scope
202	ELEVATOR	5	C	1	E/5	8'-0"	
203	CORNER ROOM	5	C	1	E/5	8'-0"	
204	ATM ROOM	5	C	1	E/5	8'-0"	
205	AVP LOAN OFFICER	5	C	1	B/2	8'-6"	
207	INDIRECT LOAN SUPPORT	5	C	1	B/2	8'-6"	
208	CONFERENCE ROOM	5	C	1	B/2	8'-6"	
209	SUPPORT #1	5	C	1	A/1	11'-6"	
210	SR. VICE PRESIDENT	5	C	1	B/2	8'-6"	
211	SUPPORT #2	5	C	1	A/1	11'-6"	
212	AVP BUS. DEVELOPMENT	5	C	1	B/2	8'-6"	
213	SUPPORT #3	5	C	1	A/1	11'-6"	
214	WAITING #1	5	C	1	A/1	11'-6"	
215	HALL	5	A	1	E/5	8'-0"	
216	STAIRS	5	C	1	-	-	
219	BOOKLIFT	5	C	1	-	-	
220	WOMEN'S TOILET	5	B	1	E/5	8'-0"	
222	MEN'S TOILET	5	B	1	E/5	8'-0"	
223	COIN WRAPPER ROOM	5	A	1	E/5	8'-0"	
224	STORAGE	5	A	1	E/5	8'-0"	
225	DRIVE UP TELLERS	5	A	1	E/5-F	8'-0"	FROM LEVEL II
226	COIN COUNTER	5	A	1	E/5	8'-0"	FROM LEVEL II
227	TELLERS	5	A	1	A/1	9'-0"	
228	PUBLIC LOBBY	5	C	1	C/3	-	FROM LEVEL III
229	TELEPHONE OPERATOR	5	C	1	A/1	11'-6"	
230	CHECK DESK	5	C	1	A/1	11'-6"	
231	WAITING #2	5	C	1	A/1	11'-6"	
232	COUPON BOOTH #1	5	C	1	B/2	8'-0"	
233	COUPON BOOTH #2	5	C	1	B/2	8'-0"	
234	S.D. VAULT	5	A	2	G	8'-0"	
235	CASH VAULT	5	A	2	G	8'-0"	
236	OFFICE #1	5	C	1	B/2	8'-6"	
237	OFFICE #2	5	C	1	B/2	8'-6"	
238	CSR #1	5	C	1	A/1	11'-6"	
239	CSR #2	5	C	1	A/1	11'-6"	
240	REAL ESTATE SUPPORT	5	C	1	A/1	11'-6"	
241	REAL ESTATE #1	5	C	1	B/2	8'-6"	
243	REAL EST. CONF. ROOM	5	C	1	B/2	8'-6"	
244	REAL ESTATE #2	5	C	1	B/2	8'-6"	
245	STAIRS	5	A	3	-	-	

LEGEND

FLOOR	BASE	WALLS	CEILING
1. CARPET (BY I.W.C.)	A. RUBBER	1. GYPSUM BRD.	A. 24 x 24 x 3/4 TYPE 1
2. MARBLE	B. CERAMIC	2. EXP. CONCRETE	B. 24 x 24 x 3/4 TYPE 2
3. RESILIENT	C. WOOD	3. CONG. BLOCK	C. 24 x 24 x 3/4 TYPE 3
4. CERAMIC TILE		4. GLASS	D. 24 x 48 x 3/4 TYPE 4
5. MAT			E. 24 x 48 x 3/4 TYPE 5
6. EXP. CONCRETE			F. GYPSUM BOARD
			G. EXP. CONCRETE
			H. EXP. STRUCTURE

DATE	NO.
JUNE 25, 1992	1
JUNE 26, 1992	2
SEPTEMBER 15, 1992	3
APRIL 25, 1993	4
DATE	NO.
JUNE 25, 1992	1
JUNE 26, 1992	2
SEPTEMBER 15, 1992	3
APRIL 25, 1993	4

CONSULTANTS

DESIGNERS

CONSTRUCTION MANAGERS

CONCEPTS

1001 250 0880

1001 250 0880

RELEASED FOR CONSTRUCTION

THIS DRAWING AND THE DESIGN THEREON ARE THE SOLE PROPERTY OF THE DESIGNER. NO REPRODUCTION OR USE OF THESE DRAWINGS FOR ANY PURPOSE OTHER THAN THAT AUTHORIZED BY THE DESIGNER IS PERMITTED WITHOUT THE WRITING OF THE DESIGNER.

FLOOR PLAN - LEVEL II

A NEW MAIN OFFICE FACILITIES FOR:


Bank of Roane County

HARRIMAN, TENNESSEE

JUNE 10, 1992

IW2

2 of 8 SHEETS

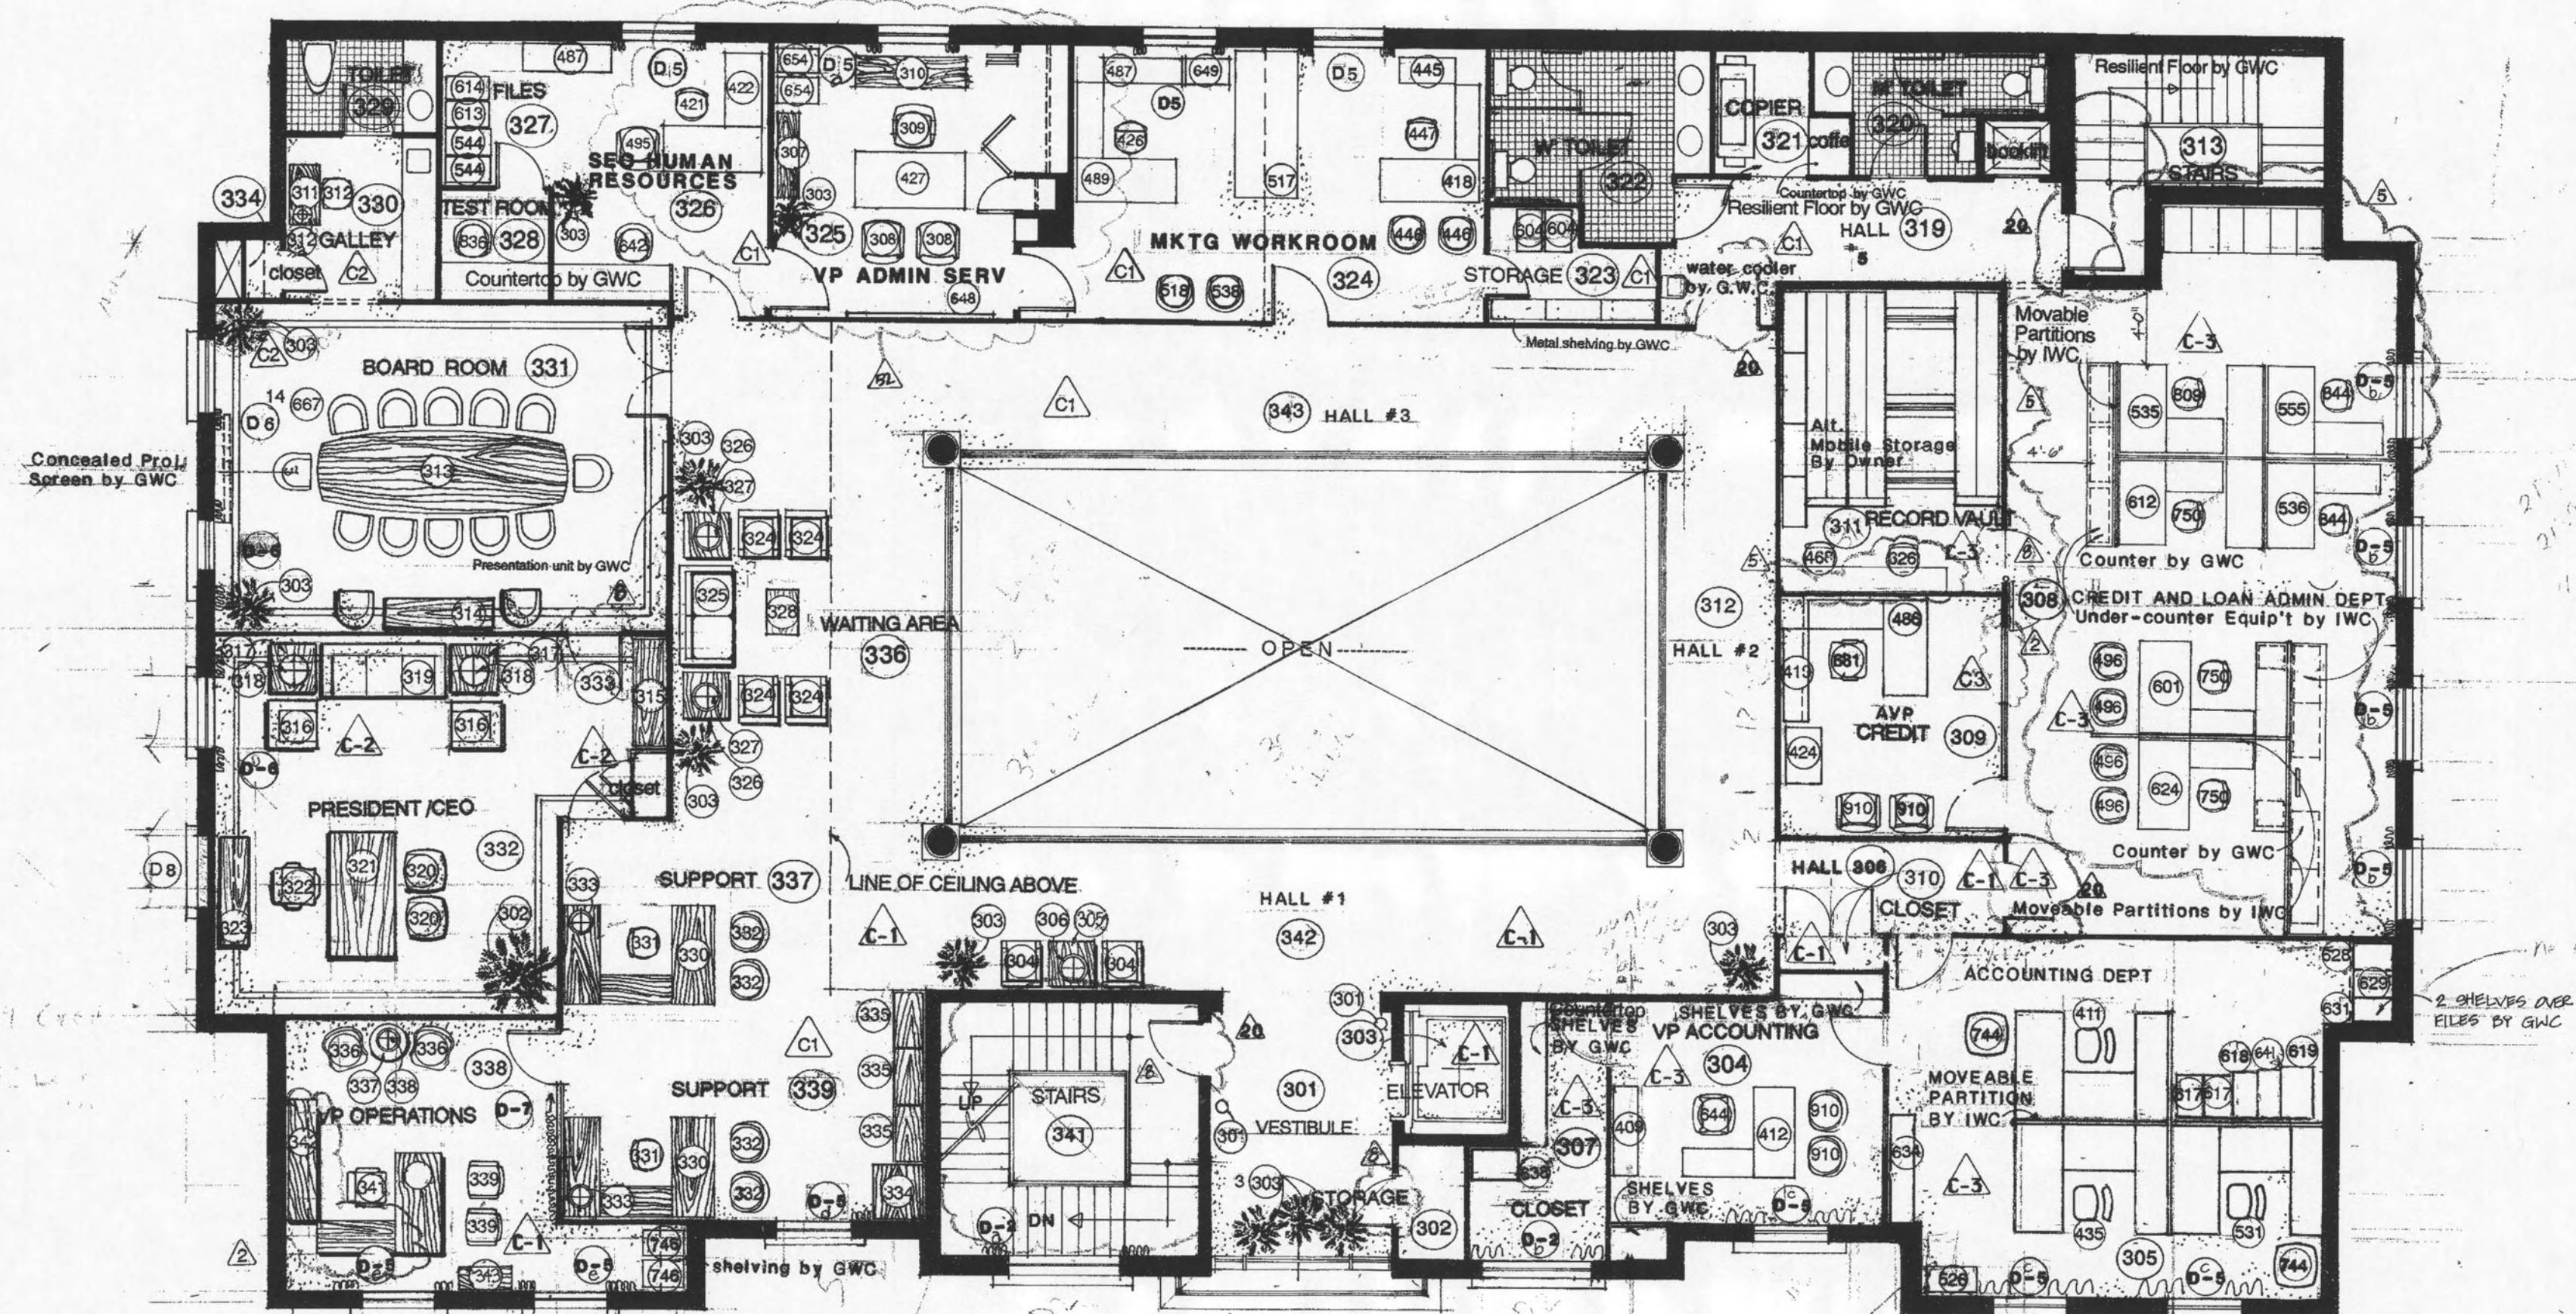


Floor Plan - LEVEL III

SCALE: 1/8" = 1'-0" Refer to architectural floor plans for dimensions

FLOOR PLAN LEGEND

- (-01) 1,2 or 3 = New Furniture
- (-01) New Furniture
- (-01) 4,5,6,7,8 or 9= Existing Furniture
- (-01) Carpet
- (-01) Drapery

Note: Interior plants by G.W.C. (part of landscaping)

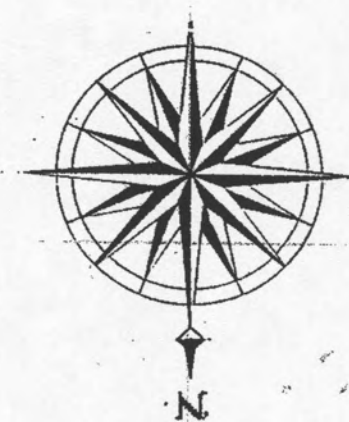

ROOM FINISH SCHEDULE

ROOM NO.	ROOM NAME	FLR.	BASE	WALLS	CLG.	CLG. HT.	RMKS.
301	VESTIBULE	1	C	1	A/1	9'-6"	
302	STORAGE	3	A	1	E/5	8'-0"	
303	ELEVATOR	1	C	1	B/2	8'-0"	
304	VP ACCOUNTING	1	C	1	D/4	9'-0"	
305	ACCOUNTING DEPT.	1	C	1	D/4	9'-0"	
306	HALL #4	1	C	1	D/4	9'-0"	
307	CLOSET	1	A	1	E/5	8'-0"	
308	CREDIT/LOAN ADMIN.	1	A	1	D/4	9'-0"	
309	AVP CREDIT	1	A	1	D/4	8'-0"	
310	CLOSET	1	A	1	F	8'-0"	
311	CREDIT RECORD VAULT	1	A	1	E	8'-0"	
312	HALL #2	1	C	1	A/1	9'-6"	
313	STAIRS	3	A	3	-	-	
316	BOOKLIFT	-	-	-	-	-	
319	HALL #5	1	C	1	E/5	8'-0"	
320	WOMEN'S TOILET	4	B	1	E/5	8'-0"	
321	COPY ROOM	3	A	1	E/5	8'-0"	
322	WOMEN'S TOILET	4	B	1	E/5	8'-0"	
323	MARKETING STORAGE	1	A	1	E/5	8'-0"	
324	MKTG WORK AREA	1	C	1	D/4	8'-0"	
325	VP HUMAN RESOURCES	1	C	1	B/2	8'-0"	
326	SECY HUMAN RESOUR.	1	C	1	D/4	8'-0"	
327	FILES	1	C	1	E/5	8'-0"	
328	TEST ROOM	1	A	1	D/4	8'-0"	
329	TOILET	4	B	1	A/1	8'-0"	
330	GALLERY	1	C	1	A/1-F	8'-0"	
331	BOARD ROOM	1	C	1	A/1-F	8'-0" TO 9'-6"	
332	PRESIDENT/CEO	1	C	1	A/1-F	8'-0"	
333	FILES	1	C	1	F	8'-0"	
334	CLOSET	1	C	1	F	8'-0"	
336	WAITING AREA #2	1	C	1	A/1	8'-5"	
337	ADMIN ASSIST. SUPPLY	1	C	1	A/1	8'-5"	
338	VP OPERATIONS	1	C	1	B/2	8'-0"	
339	SUPPORT	1	C	1	F	8'-5"	
341	STAIRS	3	A	3	-	-	
342	HALL #1	1	C	1	A/1-F	8'-5"	
343	HALL #3	1	C	1	A/1-F	8'-5"	

LEGEND

FLOOR	BASE	WALLS	CEILING
1. CARPET (BY LWC.)	A. RUBBER	1. GYPSUM BRD.	A. 24 x 24 x 3/4 TYPE 1
2. MARBLE	B. CERAMIC	2. EXP. CONCRETE	B. 24 x 24 x 3/4 TYPE 2
3. RESILIENT	C. WOOD	3. CONC. BLOCK	C. 24 x 24 x 3/4 TYPE 3
4. CERAMIC TILE		4. GLASS	D. 24 x 48 x 3/4 TYPE 4
5. MAT			E. 24 x 48 x 3/4 TYPE 5
6. EXP. CONCRETE			F. GYPSUM BOARD
			G. EXP. CONCRETE
			H. EXP. STRUCTURE

DATE	BY	REV
JUNE 22, 1992		
JUNE 25, 1992		
JUNE 26, 1992		
SEPTEMBER 18, 1992		
APRIL 26, 1993		

Concepts

design-build
design-build
design-build

• Consultants
• Designers
• Construction Managers

1401 256 9550
Rena George 33372
597 Russell Road

RELEASED FOR CONSTRUCTION

THIS DRAWING AND THE DESIGN THEREON ARE THE SOLE PROPERTY OF ROANE COUNTY, TENNESSEE. NO REPRODUCTION OR USE OF THESE DRAWINGS OR DESIGN THEREON FOR ANY PURPOSE OTHER THAN THAT SPECIFICALLY AUTHORIZED BY WRITING IS PROHIBITED.

FLOOR PLAN - LEVEL III

A NEW MAIN OFFICE FACILITY FOR:


Bank of Roane County

HARRIMAN, TENNESSEE

682 JUNE 10, 1992


3 OF 8 SHEETS

IW3

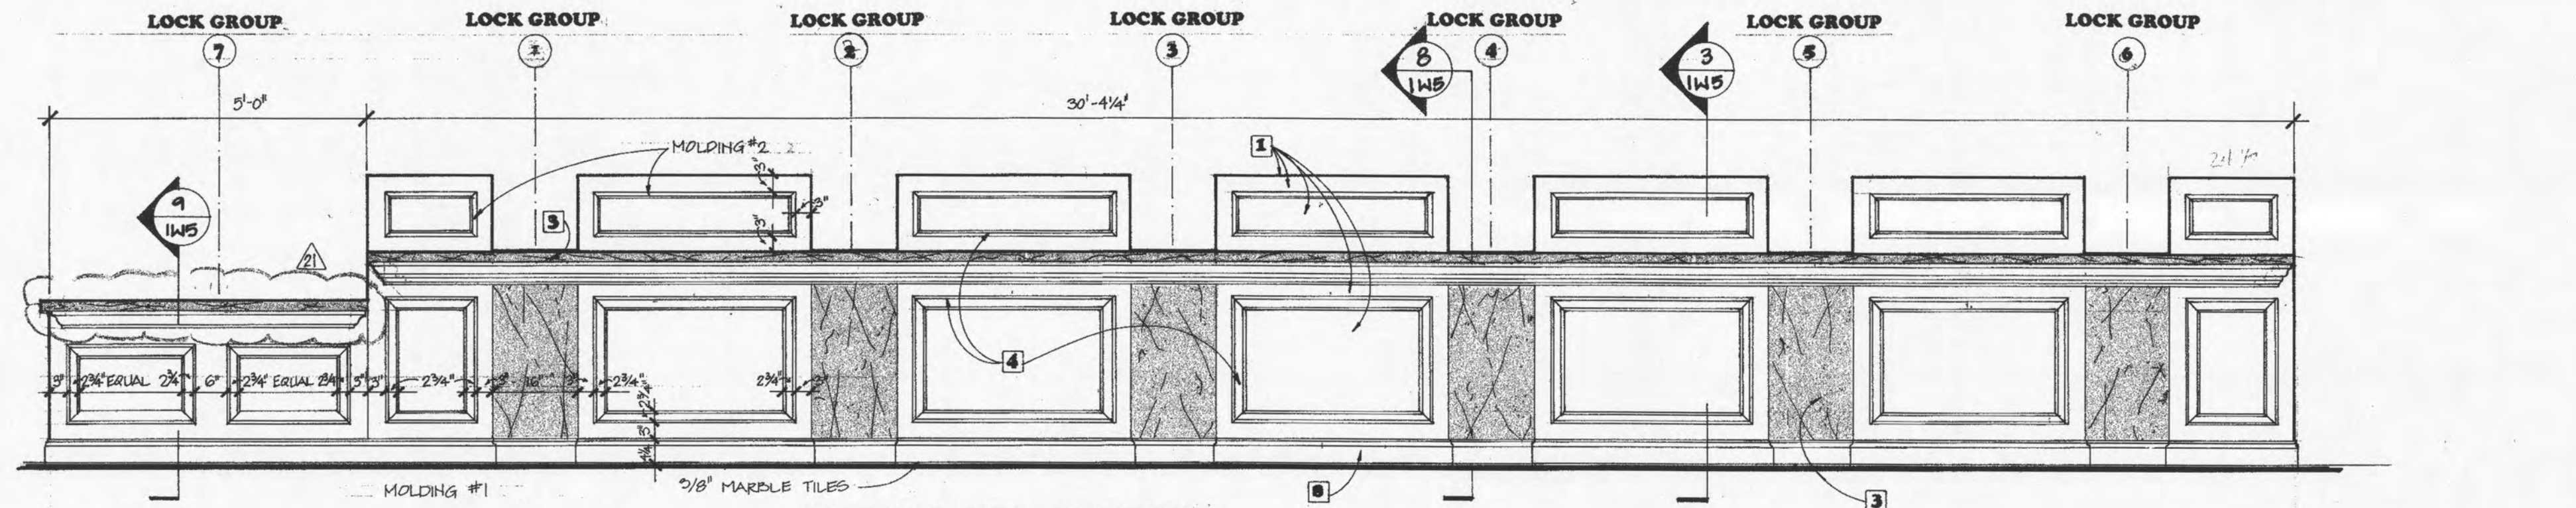

TELLER COUNTER (FRONT VIEW)


Scale: 1/2" = 1'-0"

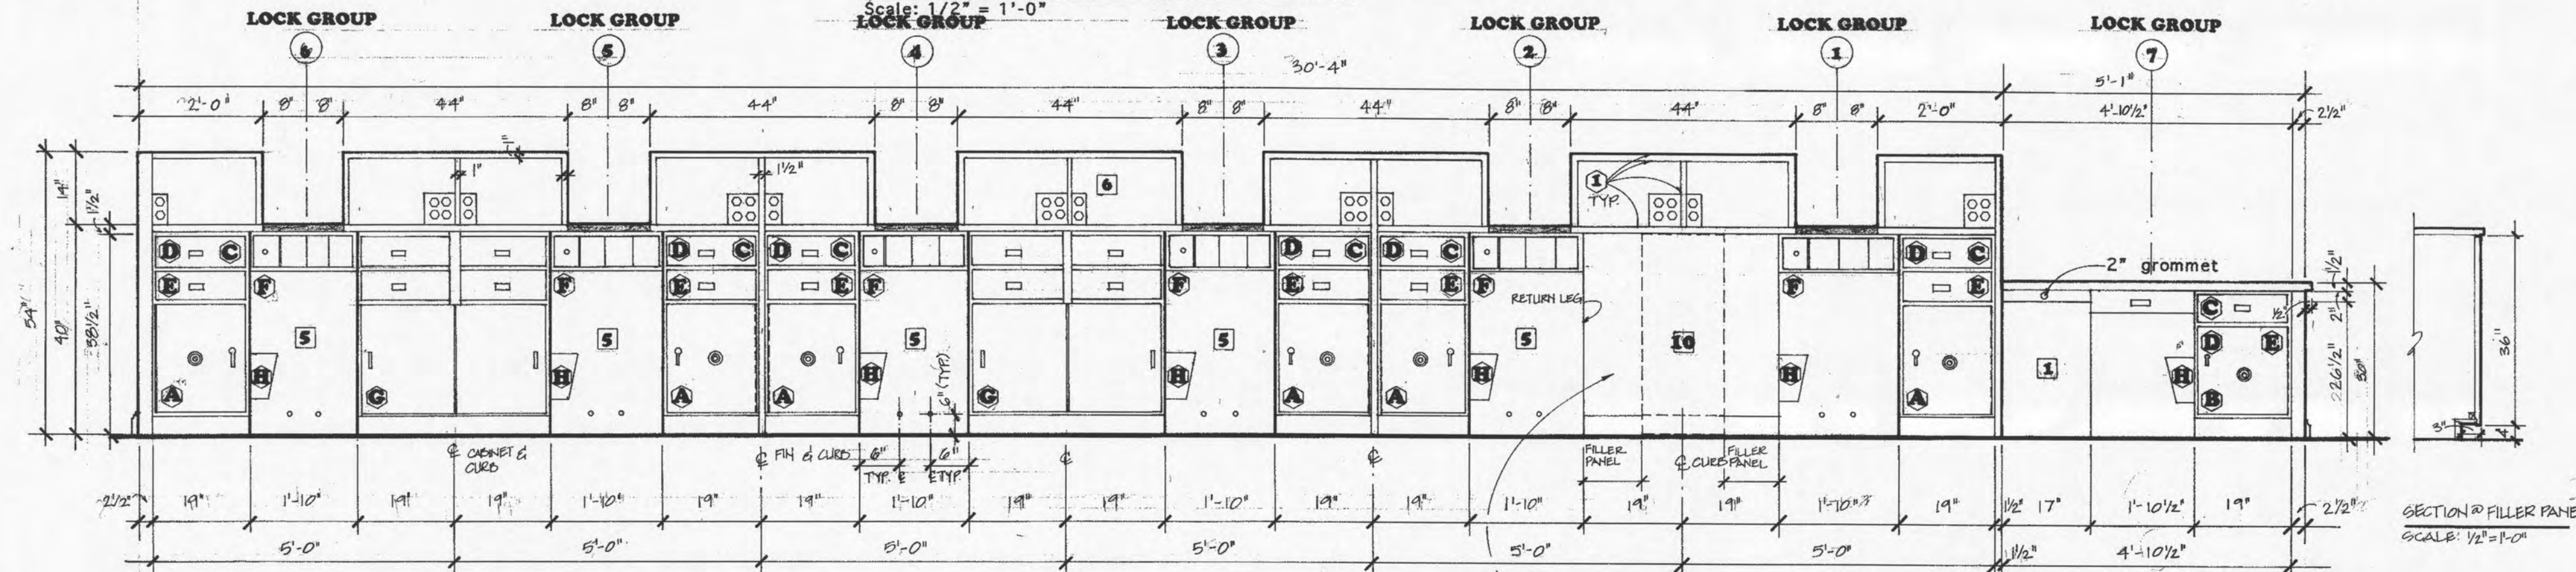

TELLER COUNTER (REAR VIEW)


Scale: 1/2" = 1'-0"

NOTE: FILLER PANEL TO BE 50\"/>

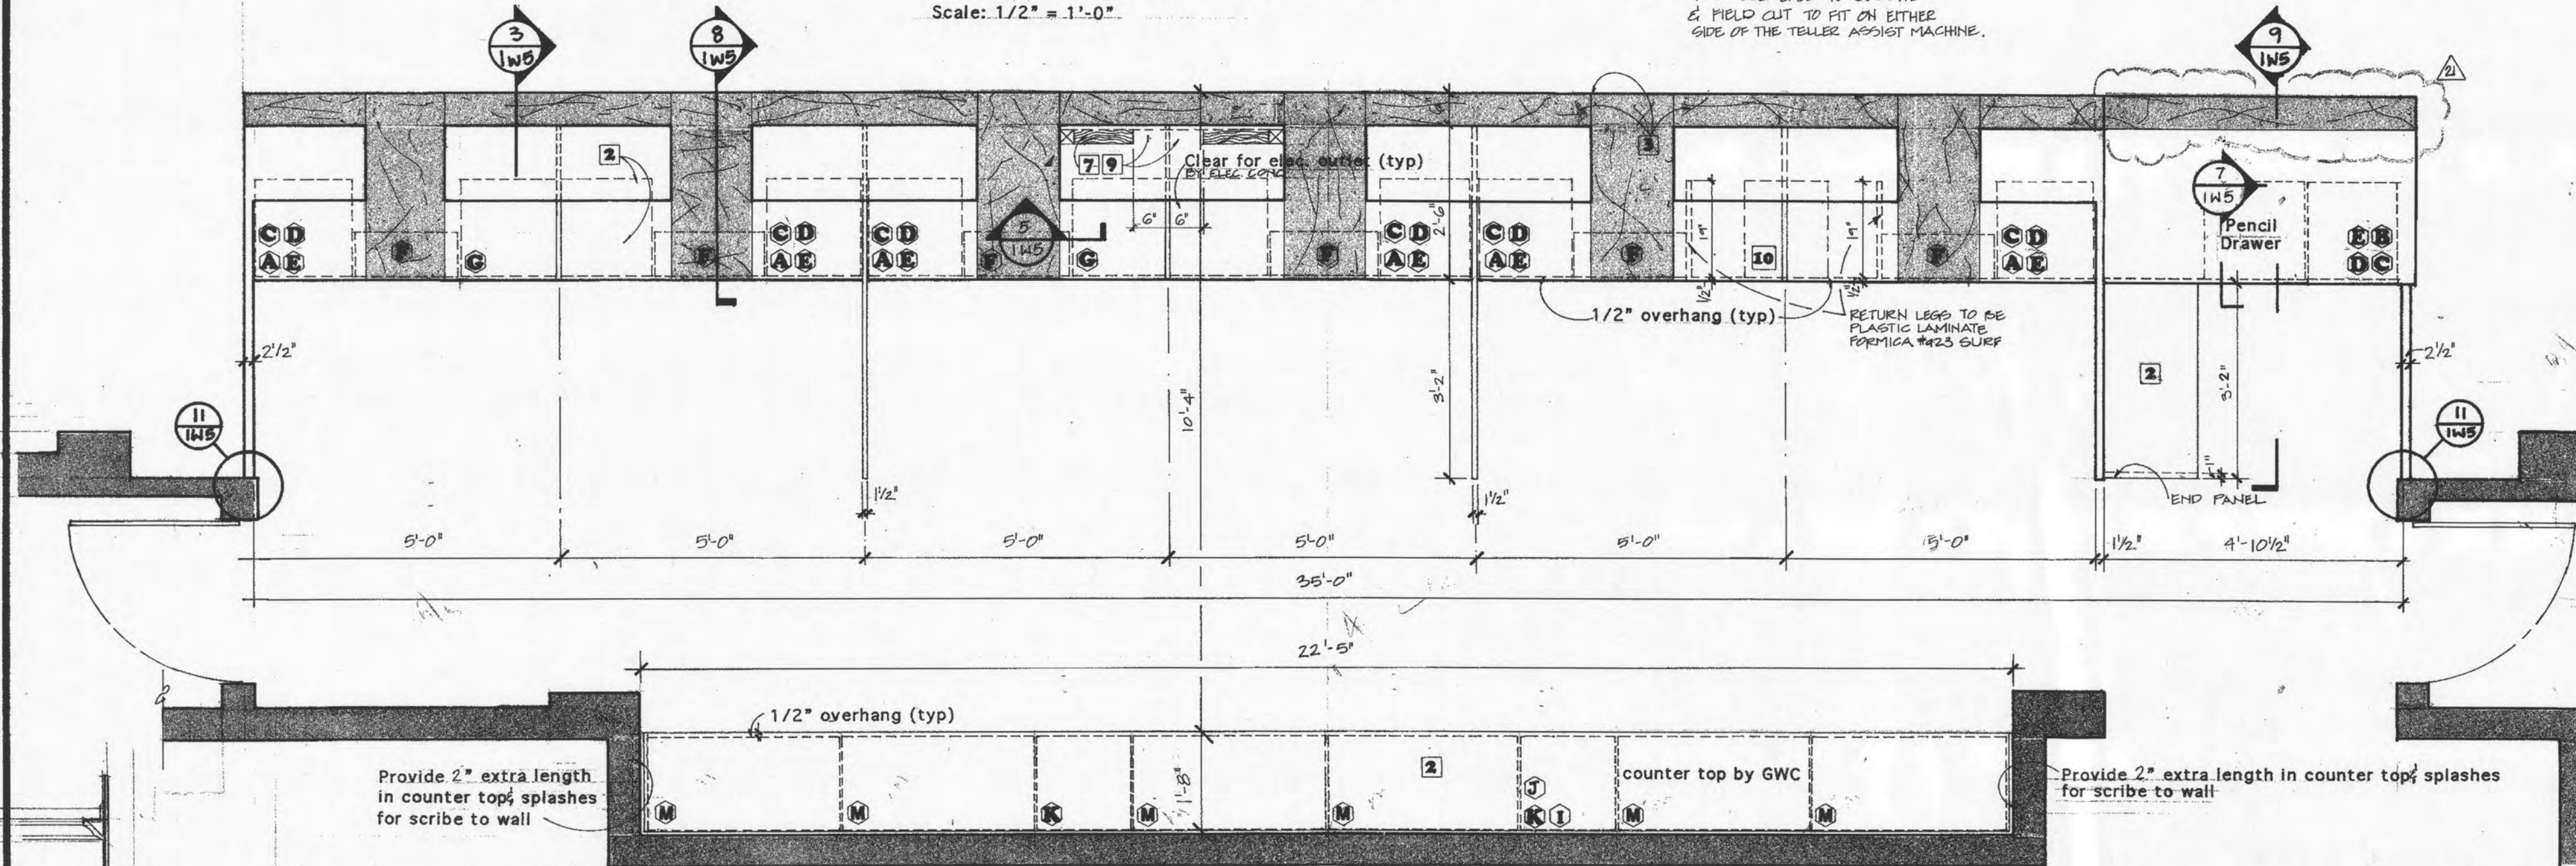

TELLER COUNTER (PLAN VIEW)

Scale: 1/2" = 1'-0"

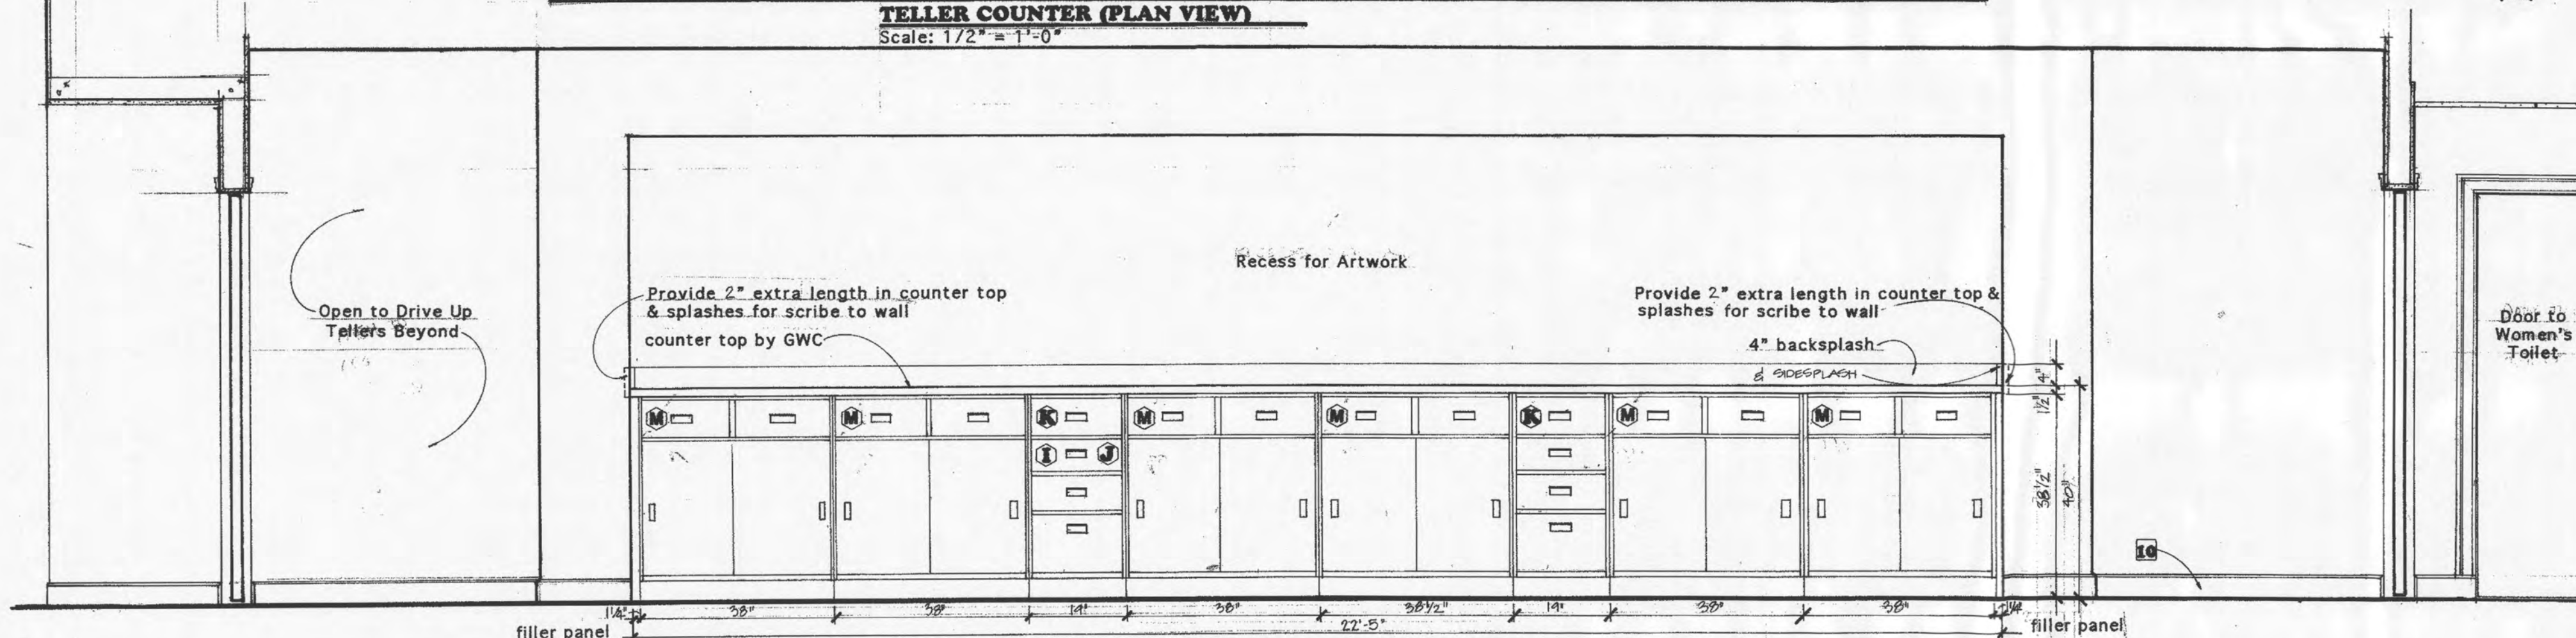

TELLER COUNTER REAR WORKSURFACE

Scale: 1/2" = 1'-0"


NOTES LEGEND

- 1 Curbs, panel insets on front of die, gate wall, return fins, under teller counter curbs and panels to be plastic laminate: Formica #923 Surf.
- 2 Teller worksurfaces and teller rear worksurfaces to be plastic laminate: Formica #923 Surf.
- 3 Desiplates, purlseedge and front panels in die to be marble: DARK ORIENTAL GREEN, AS SUPPLIED BY THE TILE & MARBLE COLLECTION, ATLANTA, GEORGIA
- 4 Applied molding on front of die to be painted SHEKHIN WILLIAMS #1017, GABEO GILVER ALYD GLOSS ENAMEL
- 5 Moveable kneespace back panel w/ two recessed finger pulls by Teller Counter Fabricator to be plastic laminate: Formica #923 Surf.
- 6 Electrical/data outlet junction boxes and covers by Electrical Contractor.
- 7 Wood furring for moveable panels by Teller Counter Fabricator.
- 8 Base molding on front of teller counter to be painted. #1017, GABEO GILVER Promar Alkyd Gloss. Base to be shipped loose and field applied by Teller Ctr. Fab.
- 9 Blocking cut 6" back at ends to allow for electrical boxes.
- 10 Teller Assist Unit by Diebold.


MARK	ORDERING NUMBER	ITEM DESCRIPTION	QTY	LOCK GROUP
A	TP-303	Cash locker w/ 2 drawers (5 w/ left hinge, 4 w/ right)	9	1,2,3,4,5,6,8,9,10
B	TP-303-1	Cash locker w/ 2 drawers sit down height, right hinge	1	7
C	CT-310	Currency tray	20	
D	CT-303	Coin scoops	10	
E	CT-211	Locking lid	20	1,2,3,4,5,6,7,8,9,10 (2.00 PER LOCK GROUP)
F	KS-104	Adj. apron w/ clip tray	6	
G	DW-103	Storage pedestal	2	
H	KS-105	Wastebasket	10	
I	CT-206	Compressor for TP-106 (for 3"x5" S.D. cards)	1	
J	CT-207	Compressor for TP-106 (for 4"x6" nite dep. cards)	1	
K	TP-106	S Drawer pedestal	2	To be determined
L		Touch up paint	2	
M	DW-102	Double Pedestal	6	

Color of all equipment to be custom: Formica #923 Surf. Each station to be keyed alike. Manufacturer: Korden, Inc.


N VI 410 CASH STORAGE W/ 10 OPENINGS, HANDLE & SHOE ON WHEELS (STAND) 1,2,3,4,5,6,7,8,9,10

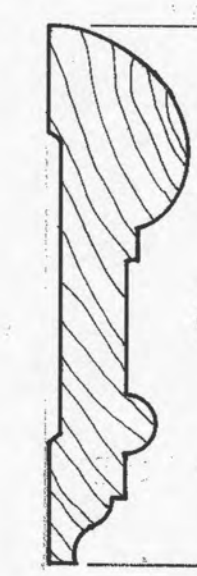


MOLDING @ FRONT OF DIE #1

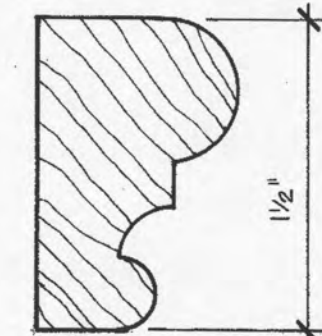

MOLDING @ CURB #2

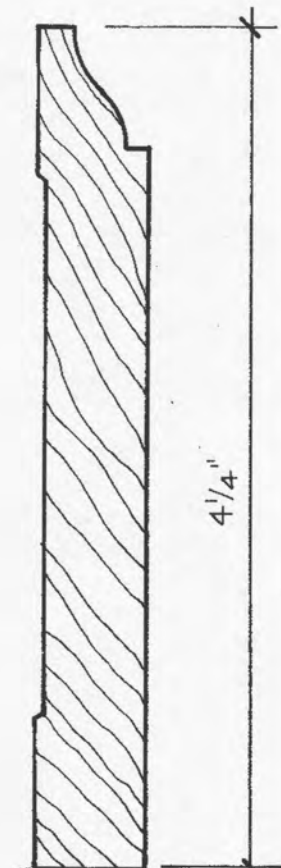

BASE MOLDING #3

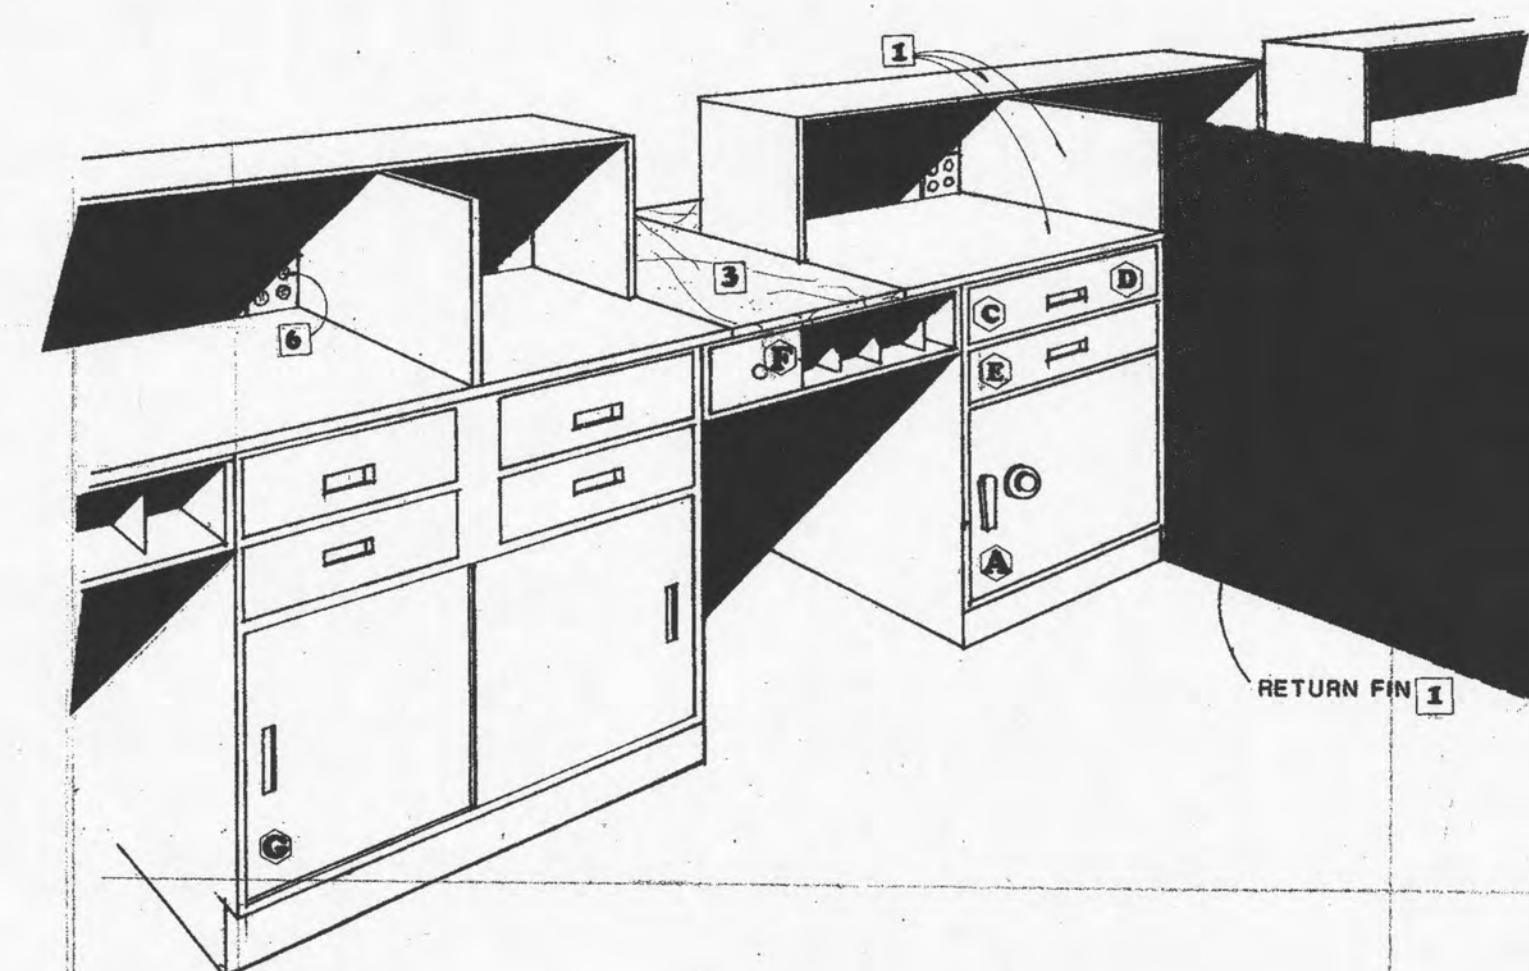

TELLER COUNTER (REAR VIEW PERSPECTIVE)

NO SCALE

RELEASED FOR CONSTRUCTION

This drawing and the designs herein are the sole property of the design firm and are not to be reproduced or used in any form without the written consent of the design firm. For any person other than the specifically authorized person, writing is prohibited.

TELLER COUNTER ELEVATIONS, PLANS & GEN NOTES

A NEW MAIN OFFICE FACILITY FOR :

Bank of Roane County
HARRIMAN, TENNESSEE

October 27, 1992

IW4


3/8\"/>


Consultants
• Designers
• Construction Managers

Concepts
design-build
design-build
design-build


Atlanta, Georgia 30312

 Form 343
10/15/92
checklist
date by
LV




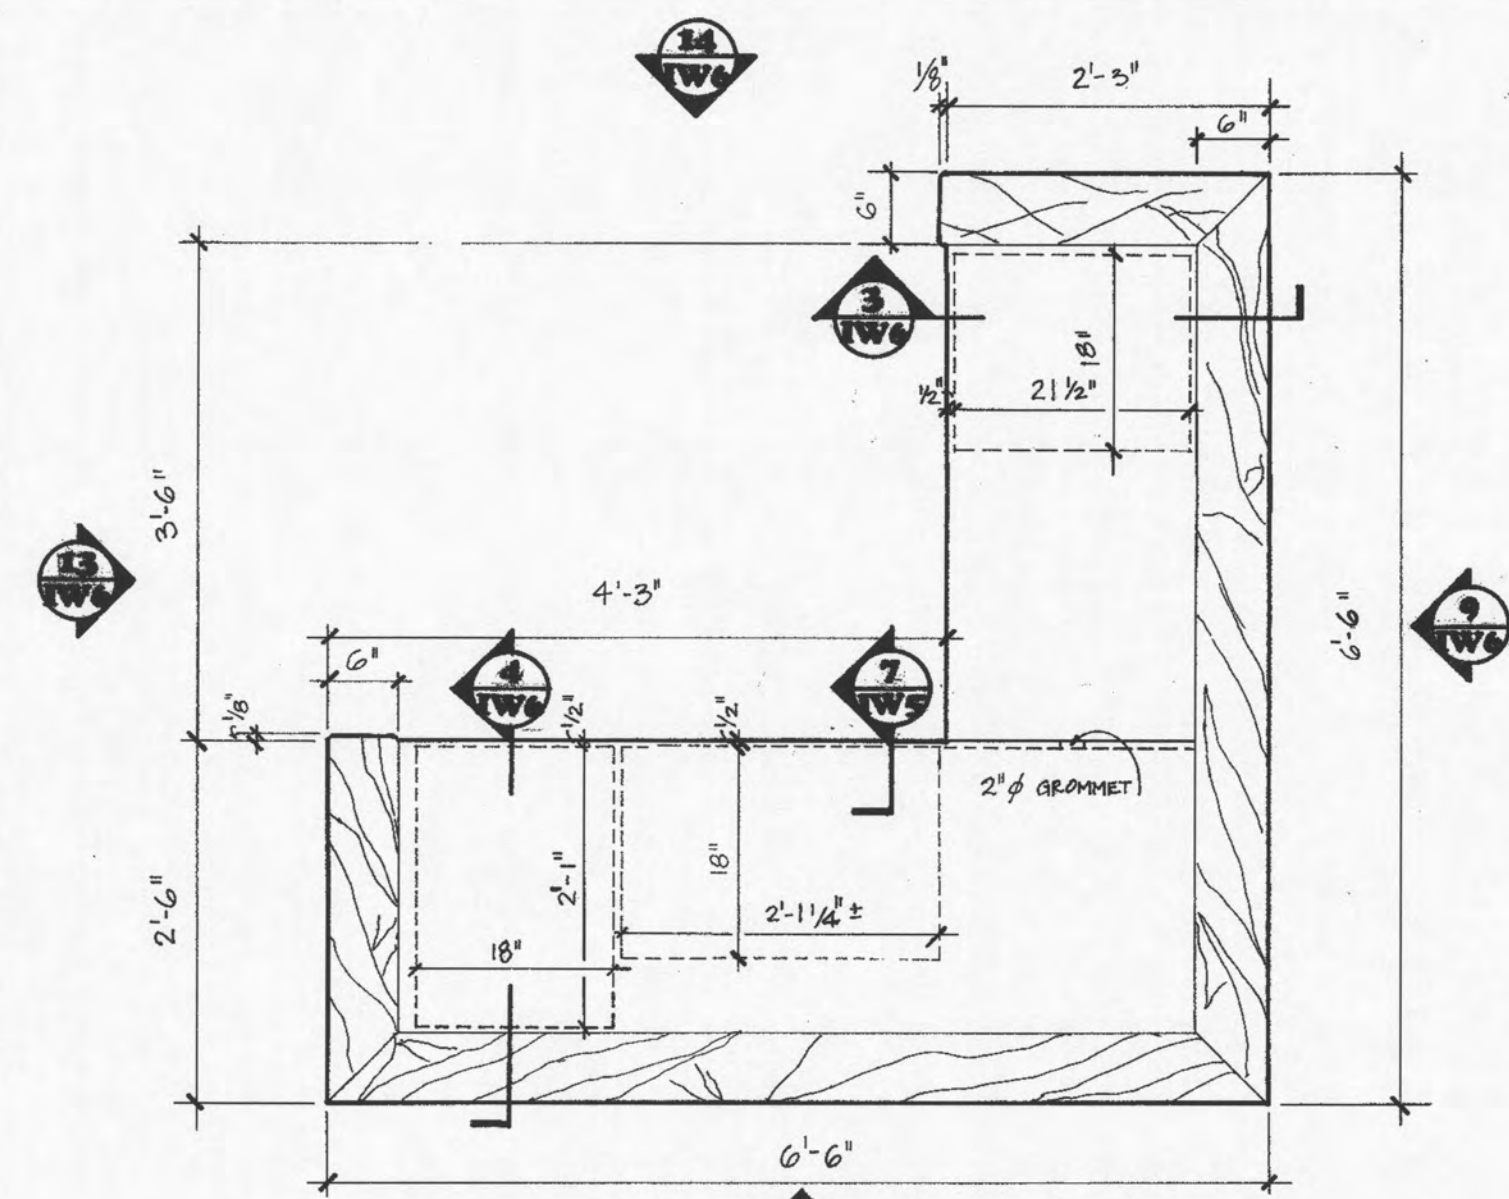


1 RECEPTION DESK - PLAN VIEW
 IWB SCALE: 3/4" = 1'-0"

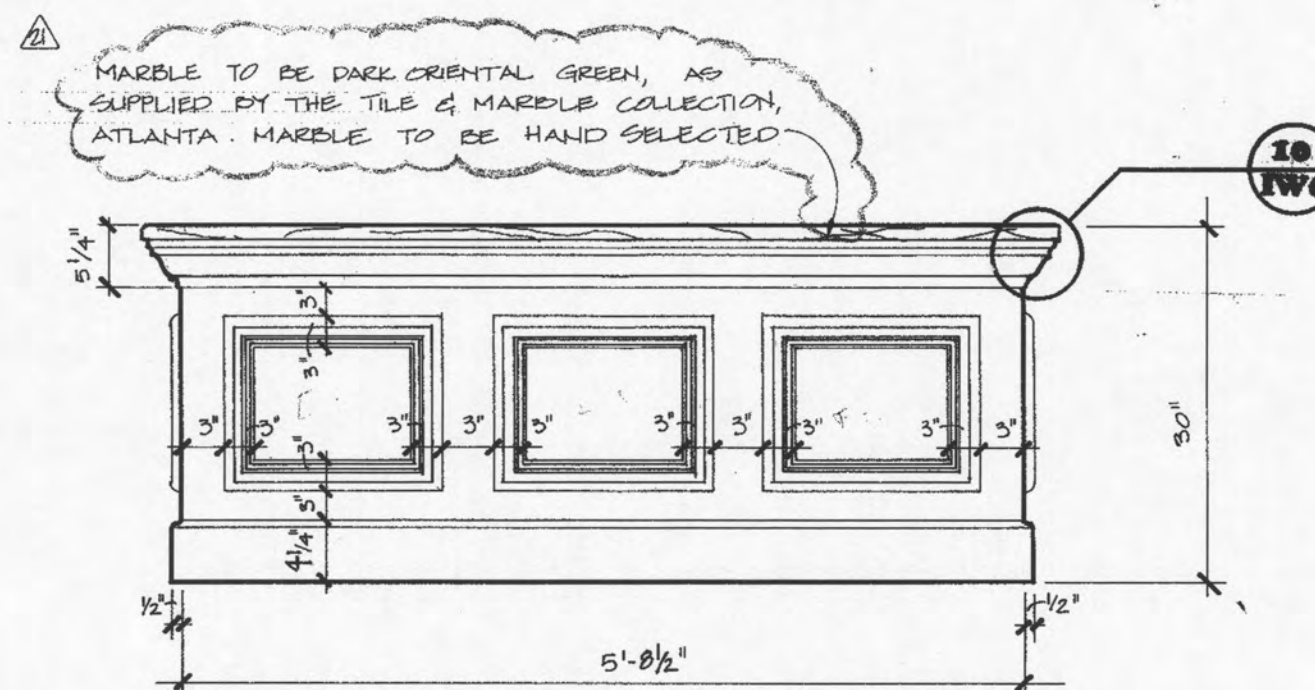


2 CHECK DESK - PLAN VIEW
 IWB SCALE: 3/4" = 1'-0"

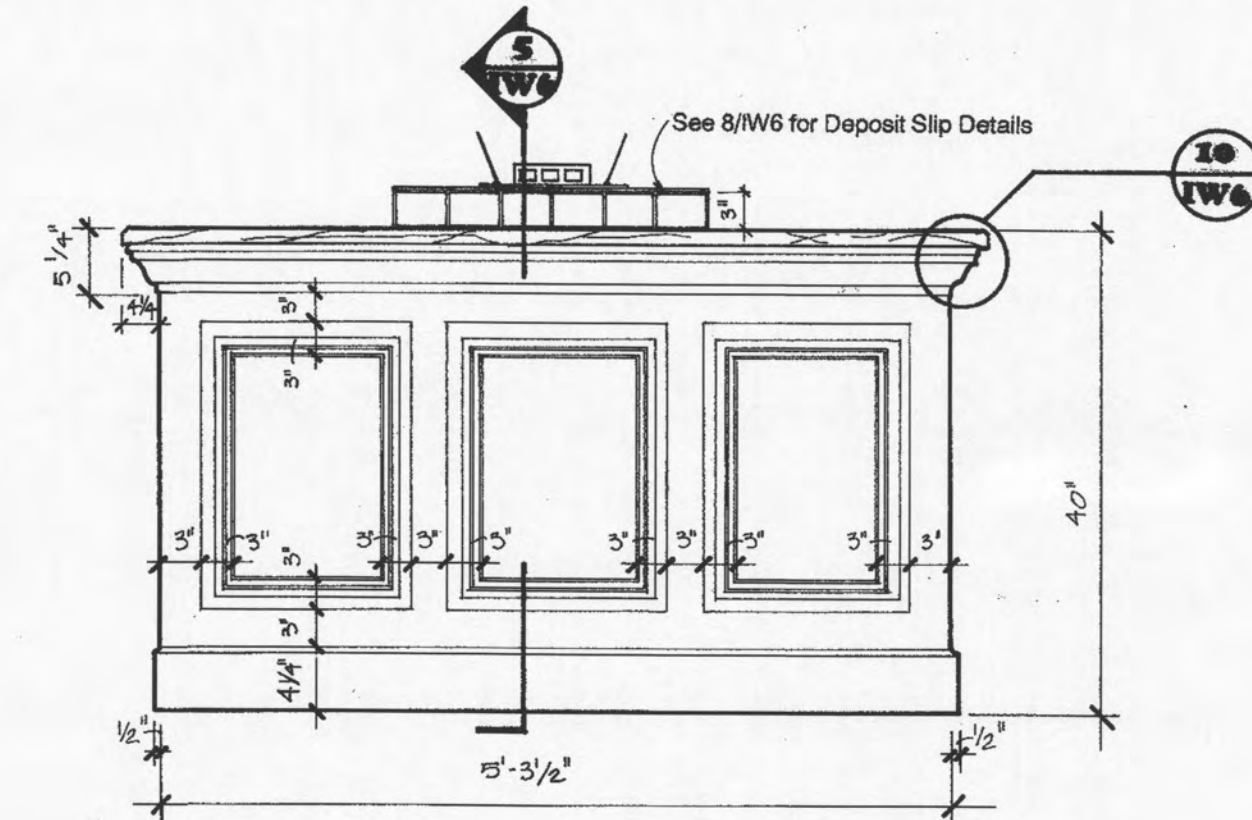

3 SECTION OF RECEPTION DESK
 IWB SCALE: 1" = 1'-0"

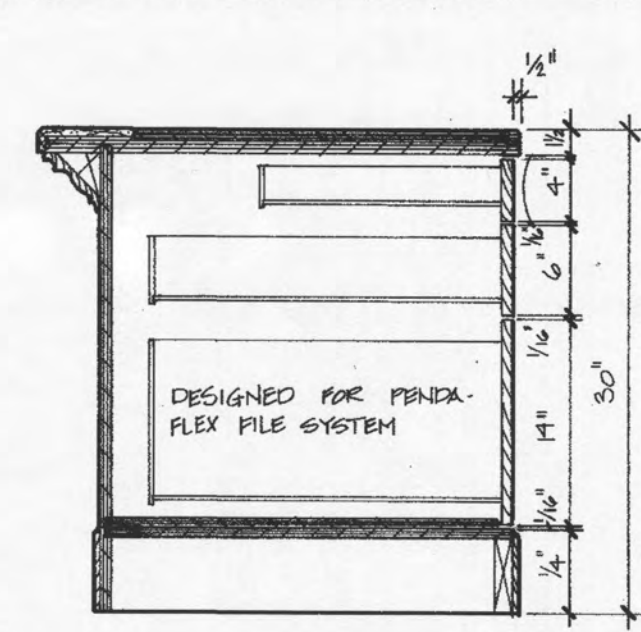


4 SECTION OF RECEPTION DESK
 IWB SCALE: 1" = 1'-0"

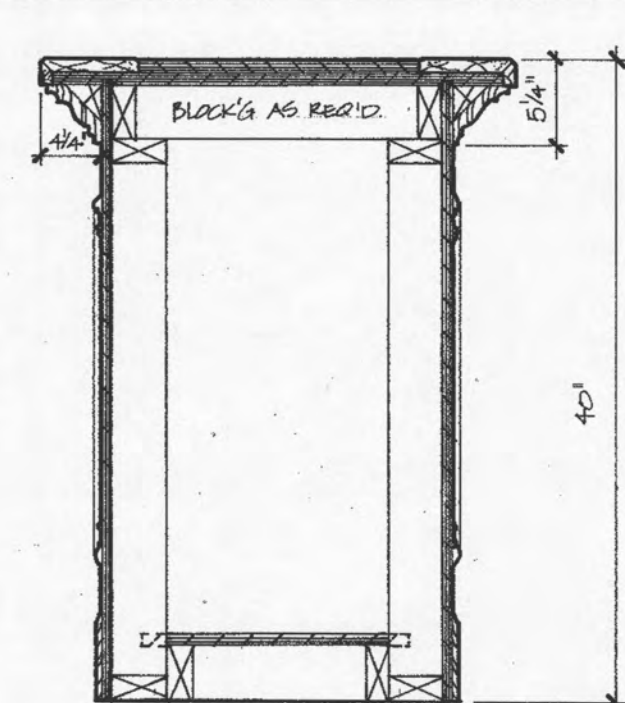

5 SECTION THRU CHECK DESK
 IWB SCALE: 1" = 1'-0"


9 RECEPTION DESK - ELEVATION
 IWB SCALE: 3/4" = 1'-0"

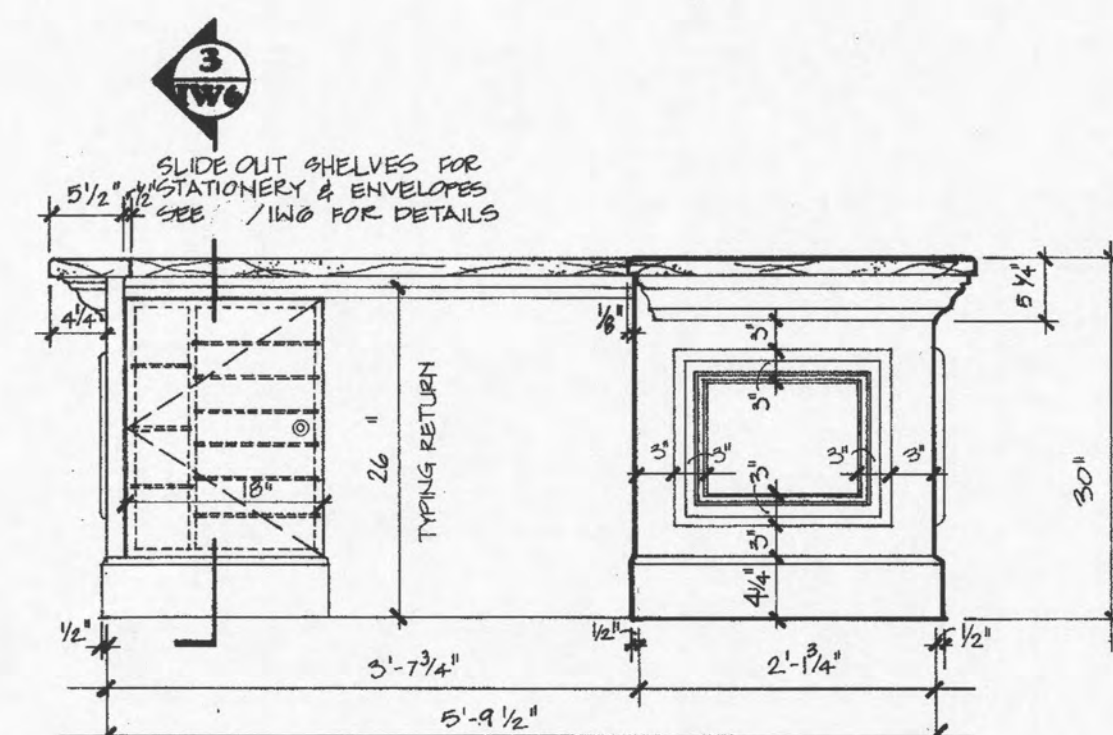


10 CHECK DESK - FRONT ELEVATION
 IWB SCALE: 3/4" = 1'-0"

7 CHECK DESK SIDE ELEVATION
 IWB SCALE: 3/4" = 1'-0"

8 PLAN VIEW OF DEPOSIT SLIP HOLDER
 IWB SCALE: 3" = 1'-0"

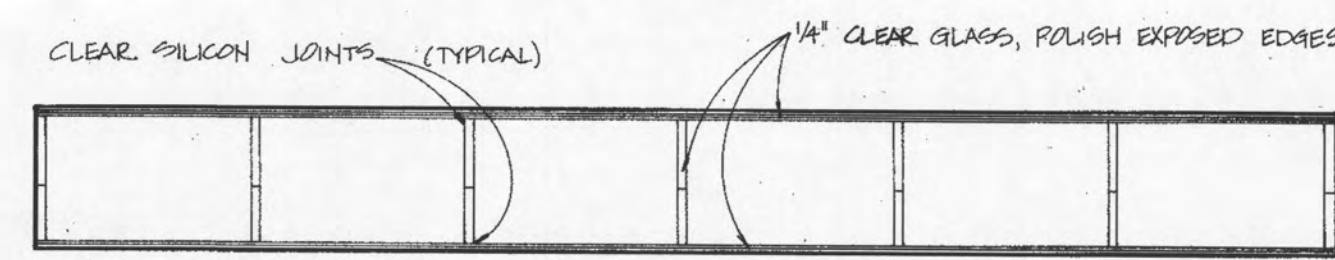


11 SECTION @ DEPOSIT SLIP HOLDER
 IWB SCALE: 3" = 1'-0"

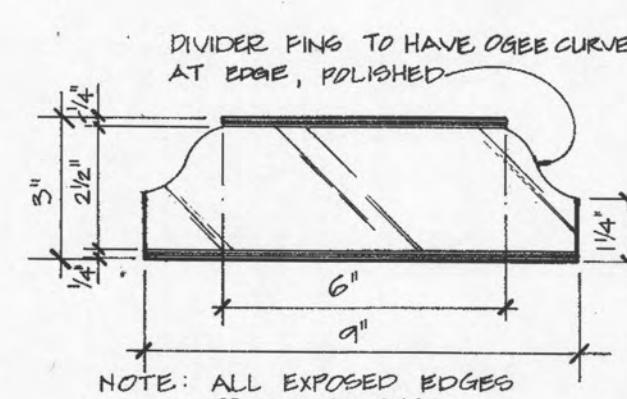


12 SIDE VIEW
 IWB SCALE: 3" = 1'-0"



13 RECEPTION DESK - ELEVATION
 IWB SCALE: 3/4" = 1'-0"

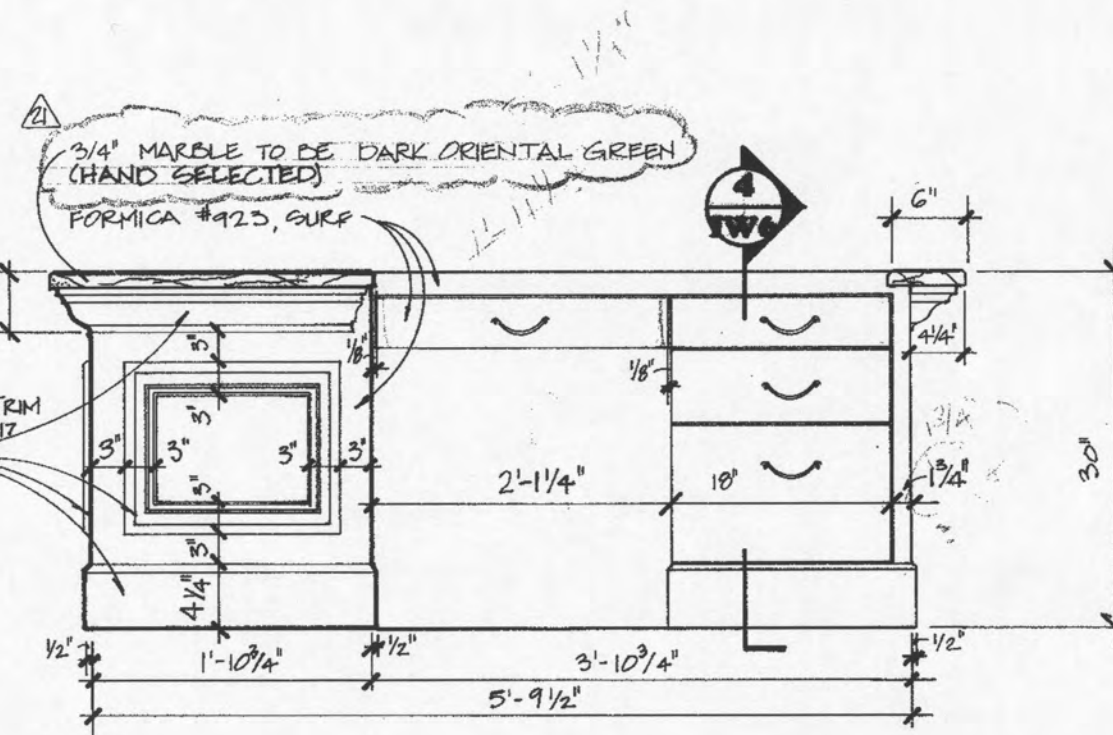

14 RECEPTION DESK - ELEVATION
 IWB SCALE: 3/4" = 1'-0"

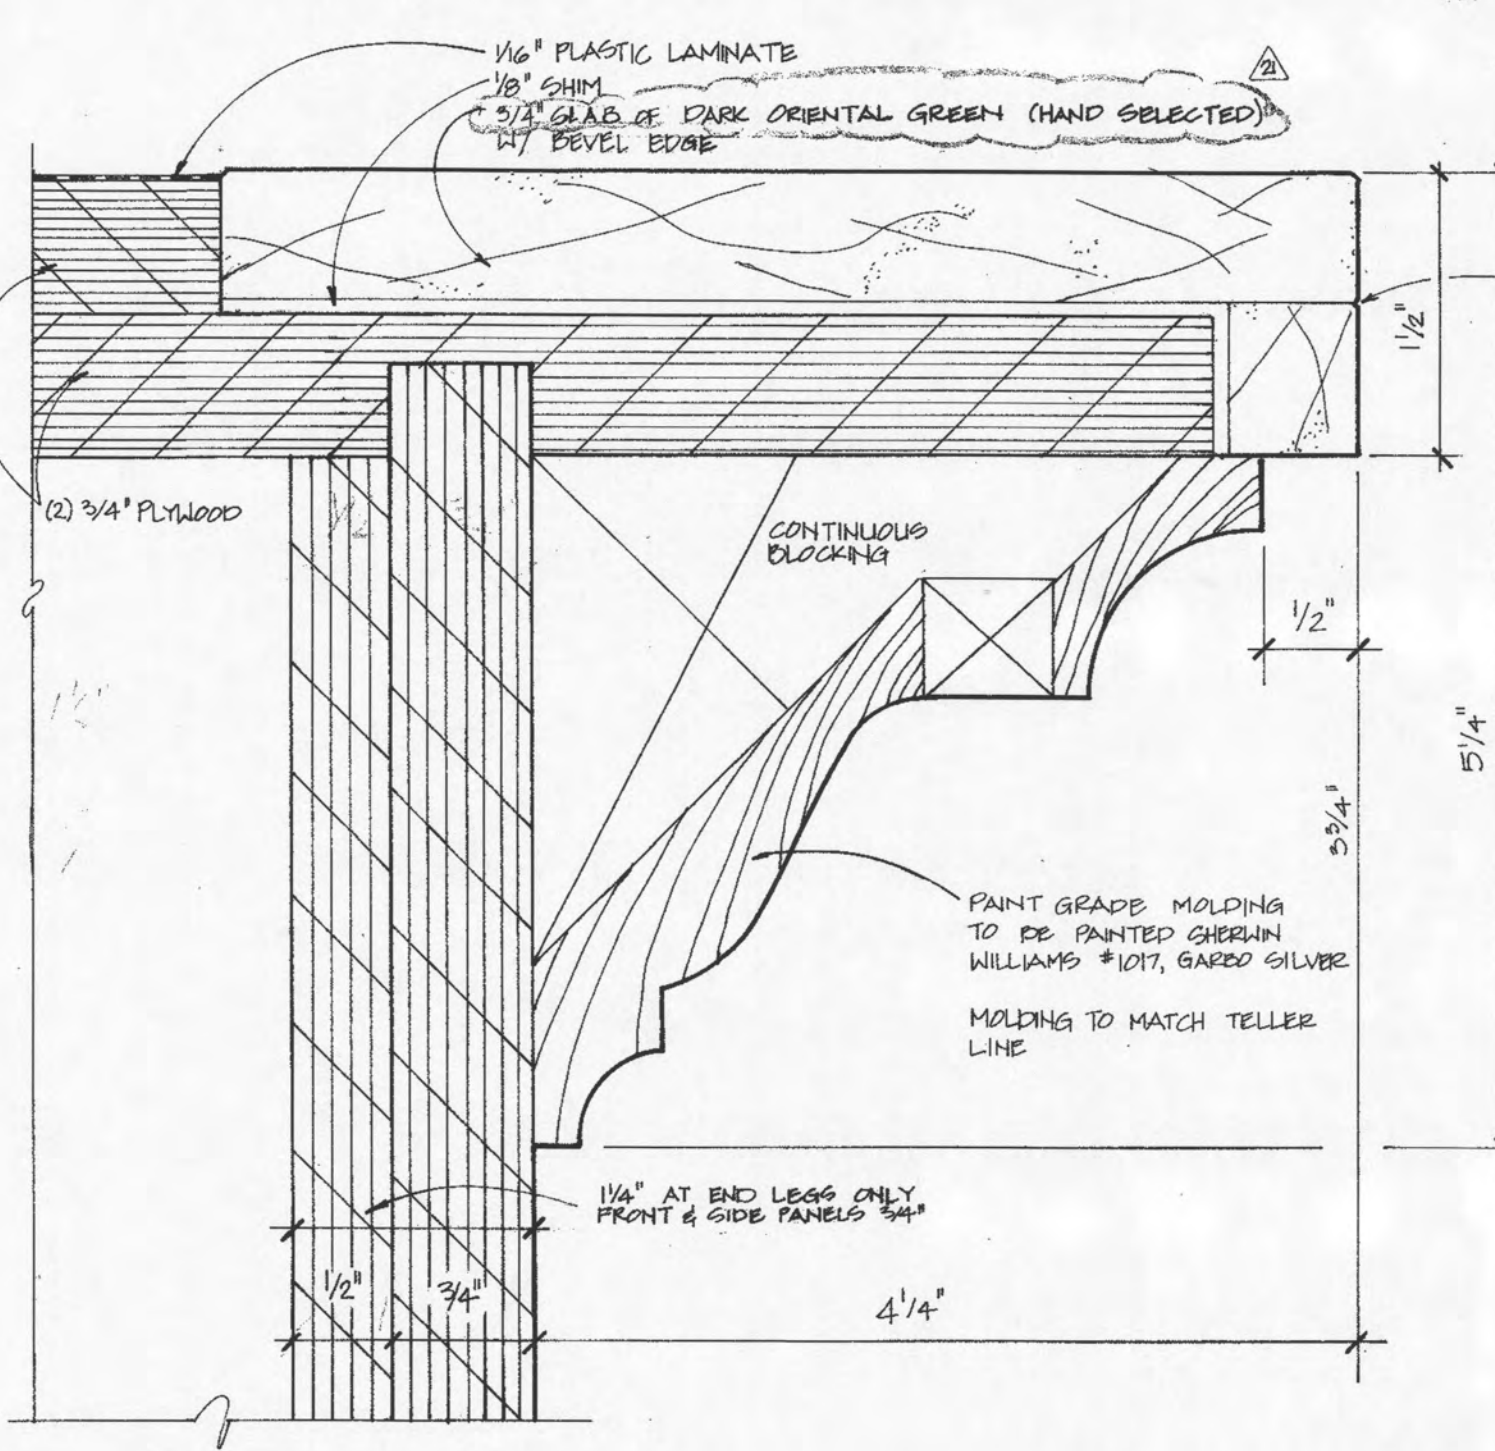


UNDER COUNTER EQUIP'T @ CREDIT & LOAN ADMIN.

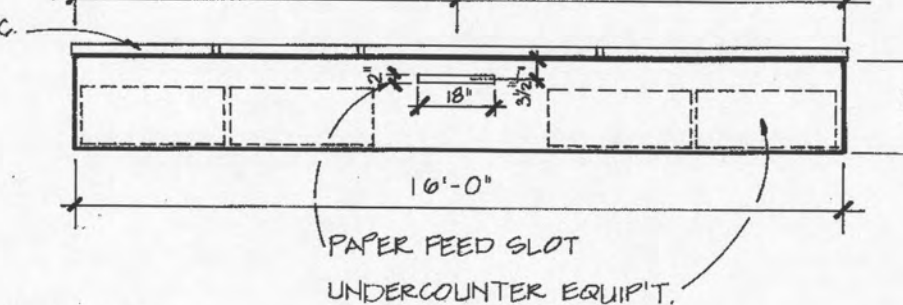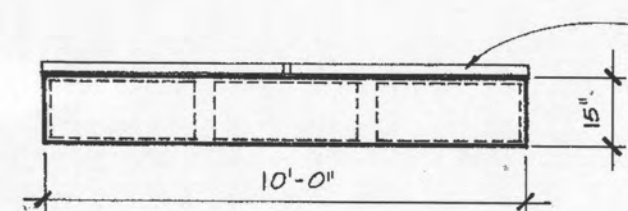


15 PLAN VIEW OF COUNTERTOP 'A'
 IWB Scale: 1/4" = 1'-0"

16 PLAN VIEW OF COUNTERTOP 'B'
 IWB Scale: 1/4" = 1'-0"

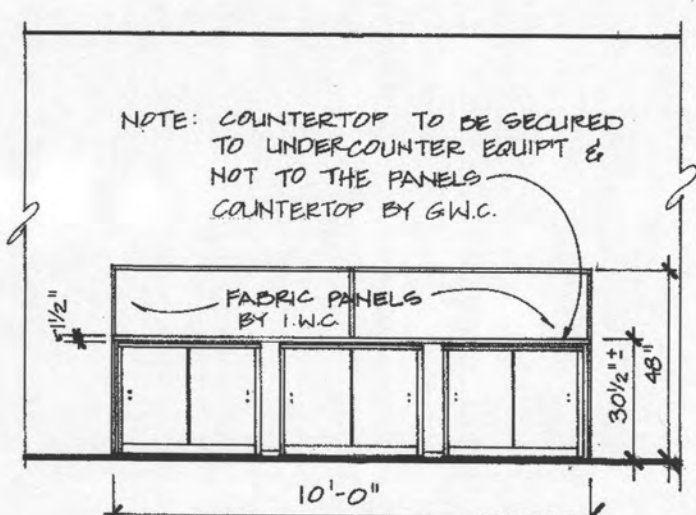

17 ELEVATION OF COUNTERTOP 'A'
 IWB Scale: 1/4" = 1'-0"

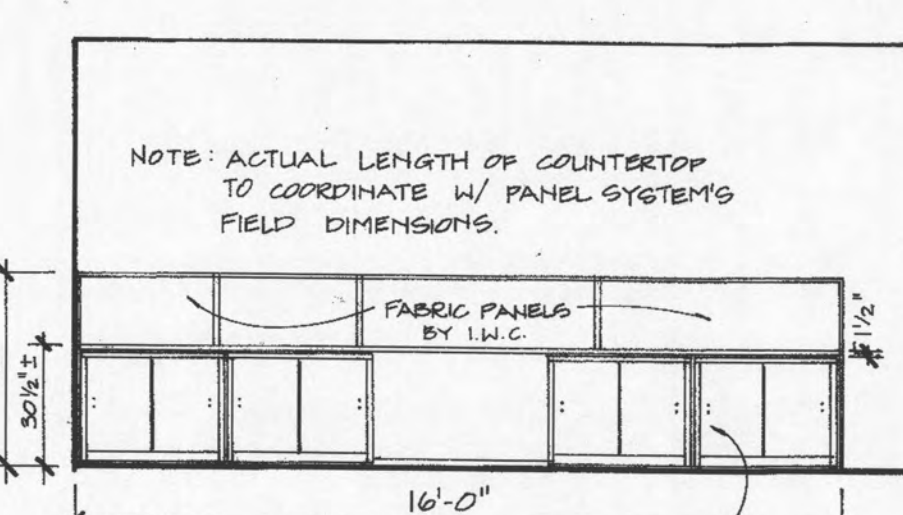

18 ELEVATION OF COUNTERTOP 'B'
 IWB Scale: 1/4" = 1'-0"

10 DETAIL @ MARBLE/PLASTIC LAMINATE
 IWB FULL SCALE

NOTE: INCLUDE LEG LEVELERS FOR ALL FURNITURE

DATE	3/83
BY	W
CHECKED	12/12/92
DESIGNED	
CONSTRUCTED	
MAINTAINED	

Concepts
 design-build
 design-build
 design-build

• Consultants
 • Designers
 • Construction Managers

101756 (000)
 Rev. 0000 3/02

RELEASED FOR CONSTRUCTION

APPROVED: *Paul R. Rouse*

This drawing and the design information are the sole property of the design-build firm. No reproduction or use of these documents in whole or in part, without the written consent of the design-build firm, is permitted.

PLAN, ELEV., SECTIONS OF RECEPTION & CHECK DESKS

A NEW MAIN OFFICE FACILITY FOR:

Bank of Roane County
 HARRIMAN, TENNESSEE

DATE: October 27, 1992

SHEET

IWB

8 OF 6 SHEETS

AS 17/27

TYPICAL FLOOR JOINT

SCALE: NTS

EMERGENCY
EXIT
→

SIGN DETAIL

SCALE: NTS

LEVEL II ROOM FINISH SCHEDULE

ROOM NO.	ROOM NAME	FLR.	BASE	WALLS	CLG.	HT.	FINISH
201	VESTIBULE	1	C	1	B/2	11'-6"	Fin. by Elev. Mnt.
202	ELEVATOR	1	C	1	B/2	11'-6"	
203	COPIER ROOM	1	C	1	B/2	11'-6"	
204	ATM ROOM	1	C	1	B/2	11'-6"	
205	AVP LOAN OFFICER	1	C	1	B/2	11'-6"	
207	INDIRECT LOAN SUPPORT	1	C	1	B/2	11'-6"	
208	CONFERENCE ROOM	1	C	1	B/2	11'-6"	
209	SUPPORT #1	1	C	1	B/2	11'-6"	
210	SUPPORT #2	1	C	1	B/2	11'-6"	
211	SUPPORT #3	1	C	1	B/2	11'-6"	
212	AVP BUS. DEVELOPMENT	1	C	1	B/2	11'-6"	
213	SUPPORT #4	1	C	1	B/2	11'-6"	
214	WAITING #1	1	C	1	B/2	11'-6"	
215	HALL	1	C	1	B/2	11'-6"	
216	STAIRS	1	C	1	B/2	11'-6"	
219	BOOKLIFT	1	C	1	B/2	11'-6"	
220	WOMEN'S TOILET	1	C	1	B/2	11'-6"	
222	MEN'S TOILET	1	C	1	B/2	11'-6"	
223	CON. WRAPPER ROOM	1	C	1	B/2	11'-6"	
224	STORAGE	1	C	1	B/2	11'-6"	
225	DRIVE UP TELLERS	1	C	1	B/2	11'-6"	From Level II
226	CON. COUNTER	1	C	1	B/2	11'-6"	From Level II
227	TELLERS	1	C	1	B/2	11'-6"	
228	PUBLIC LOBBY	1	C	1	B/2	11'-6"	
229	TELEPHONE OPERATOR	1	C	1	B/2	11'-6"	
230	CHECK DESK	1	C	1	B/2	11'-6"	
231	WAITING #2	1	C	1	B/2	11'-6"	
232	Coupon Booth #1	1	C	1	B/2	11'-6"	
233	Coupon Booth #2	1	C	1	B/2	11'-6"	
234	S.D. VAULT	1	C	1	B/2	11'-6"	1/2
235	CASH VAULT	1	C	1	B/2	11'-6"	
236	OFFICE #1	1	C	1	B/2	11'-6"	
237	OFFICE #2	1	C	1	B/2	11'-6"	
238	CSR #1	1	C	1	B/2	11'-6"	
239	CSR #2	1	C	1	B/2	11'-6"	
240	REAL ESTATE-SUPPORT	1	C	1	B/2	11'-6"	
241	REAL ESTATE #1	1	C	1	B/2	11'-6"	
242	REAL ESTATE #2	1	C	1	B/2	11'-6"	
243	REAL ESTATE CONF. ROOM	1	C	1	B/2	11'-6"	
244	REAL ESTATE #3	1	C	1	B/2	11'-6"	
245	STAIRS	1	C	1	B/2	11'-6"	

LEGEND

FLOOR	BASE	WALLS	CEILING
1. CARPET (BY LWC.)	A. RUBBER	1. GYPSUM BRD.	A. 24" x 24" x 5/8" TYPE 1
2. MARBLE	B. CERAMIC	2. EXP. CONCRETE	B. 24" x 24" x 5/8" TYPE 2
3. RESILIENT	C. WOOD	3. CONC. BLOCK	C. 24" x 24" x 5/8" TYPE 3
4. CERAMIC TILE	D. GLASS	4. GLASS	D. 24" x 24" x 5/8" TYPE 4
5. MAT	E. EXP. CONCRETE	E. EXP. CONCRETE	E. 24" x 24" x 5/8" TYPE 5
6. EXP. CONCRETE	F. EXP. CONCRETE	F. EXP. CONCRETE	F. EXP. CONCRETE
	G. EXP. CONCRETE	G. EXP. CONCRETE	G. EXP. CONCRETE
	H. EXP. STRUCTURE	H. EXP. STRUCTURE	H. EXP. STRUCTURE

REMARKS

1. SPRAYTEXTURE CEILING (BY GWS CONTRACTOR)
2. SPRAYTEXTURE WALLS (BY GWS CONTRACTOR)

INTERIOR WALL TYPES

1. 3/8" METAL STUDS @ 16" O.C. WITH 1/2" GWS ON BOTH SIDES.
- 1A. SAME AS #1, WITH SOUND ATTENUATION BLANKET.
2. 3/8" METAL STUDS @ 16" O.C. WITH 1/2" TYPE "X" GWS ON BOTH SIDES (1-HOUR FIRE RATING).
3. 3/8" METAL STUDS @ 16" O.C. WITH 1/2" GWS ON ONE SIDE.
- 3A. SAME AS #3, WITH SOUND ATTENUATION BLANKET.
4. 7/8" CONCRETE BLOCK WITH 1/2" GWS ON ONE SIDE ONLY.
5. 7/8" PAINTED CONCRETE BLOCK WALL.
6. 8" METAL STUDS @ 16" O.C. WITH 1/2" GWS ON BOTH SIDES.
- 6A. SAME AS #6, WITH SOUND ATTENUATION BLANKET.
7. 8" METAL STUDS @ 16" O.C. WITH 1/2" GWS ON ONE SIDE ONLY.
8. 12" CONCRETE WITH 1/2" GWS ON ONE SIDE ONLY.
9. GWS SHIRT WALL - U.I. DESIGNED 1-HR (2-HOUR FIRE RATING).

NOTE: ALL WALLS ARE TYPE 1
UNLESS OTHERWISE NOTED

***** 1 HR FIRE WALL
***** 2 HR FIRE WALL

HANDRAIL DETAIL

SCALE: HALF SCALE

Floor Plan - LEVEL II

SCALE: 1/8" = 1'-0"



Legend

- FACE OF STUD / FACE OF BLOCK / CONCRETE / BRICK
- CL. OF WALL

Toilet Accessories

- HANDICAP RAIL
- TOILET PAPER HOLDERS
- TOWEL DISPENSERS/WASTE RECEPTACLES
- SOAP DISPENSER
- FEM. NAPKIN DISPOSAL

BRASS SPECIALTY ACCESSORIES

- TISSUE BOX
- OUTLET COVER PLATES
- SWITCH COVER PLATE
- SOAP DISH
- 24" TOWEL BAR

SECTION THRU SIT-DOWN

SCALE: 1" = 1'-0"



RELEASED FOR CONSTRUCTION
This drawing and the designs herein are the sole property of the undersigned and shall not be reproduced or used in any manner for any purpose other than as specifically authorized by the undersigned. Any unauthorized use or reproduction is prohibited.

FLOOR PLAN - LEVEL II

A NEW MAIN OFFICE FACILITY FOR:


Bank of Roane County
HARRIMAN, TENNESSEE



JUNE 10, 1992

A-4

Sheet 28 of 28



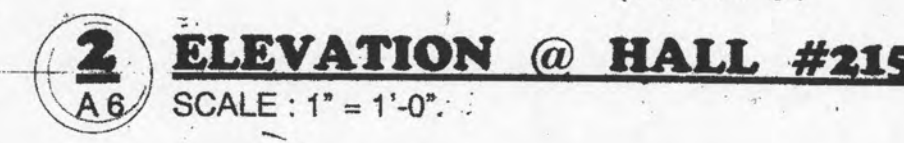

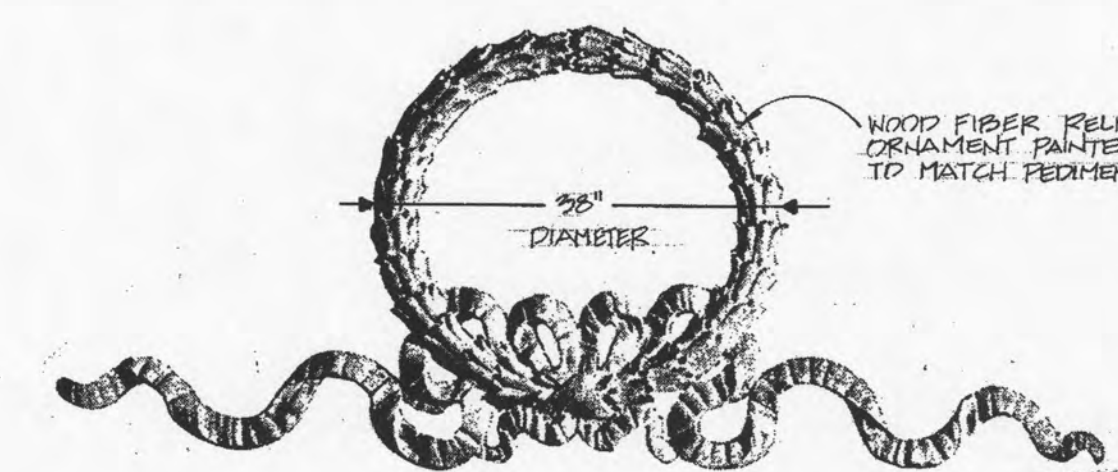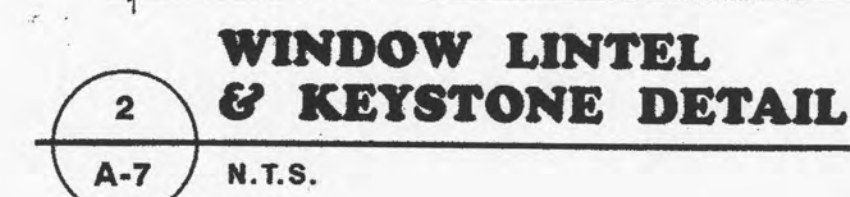

1 RELIEF ORNAMENT DETAIL
A-7 N.T.S.

