
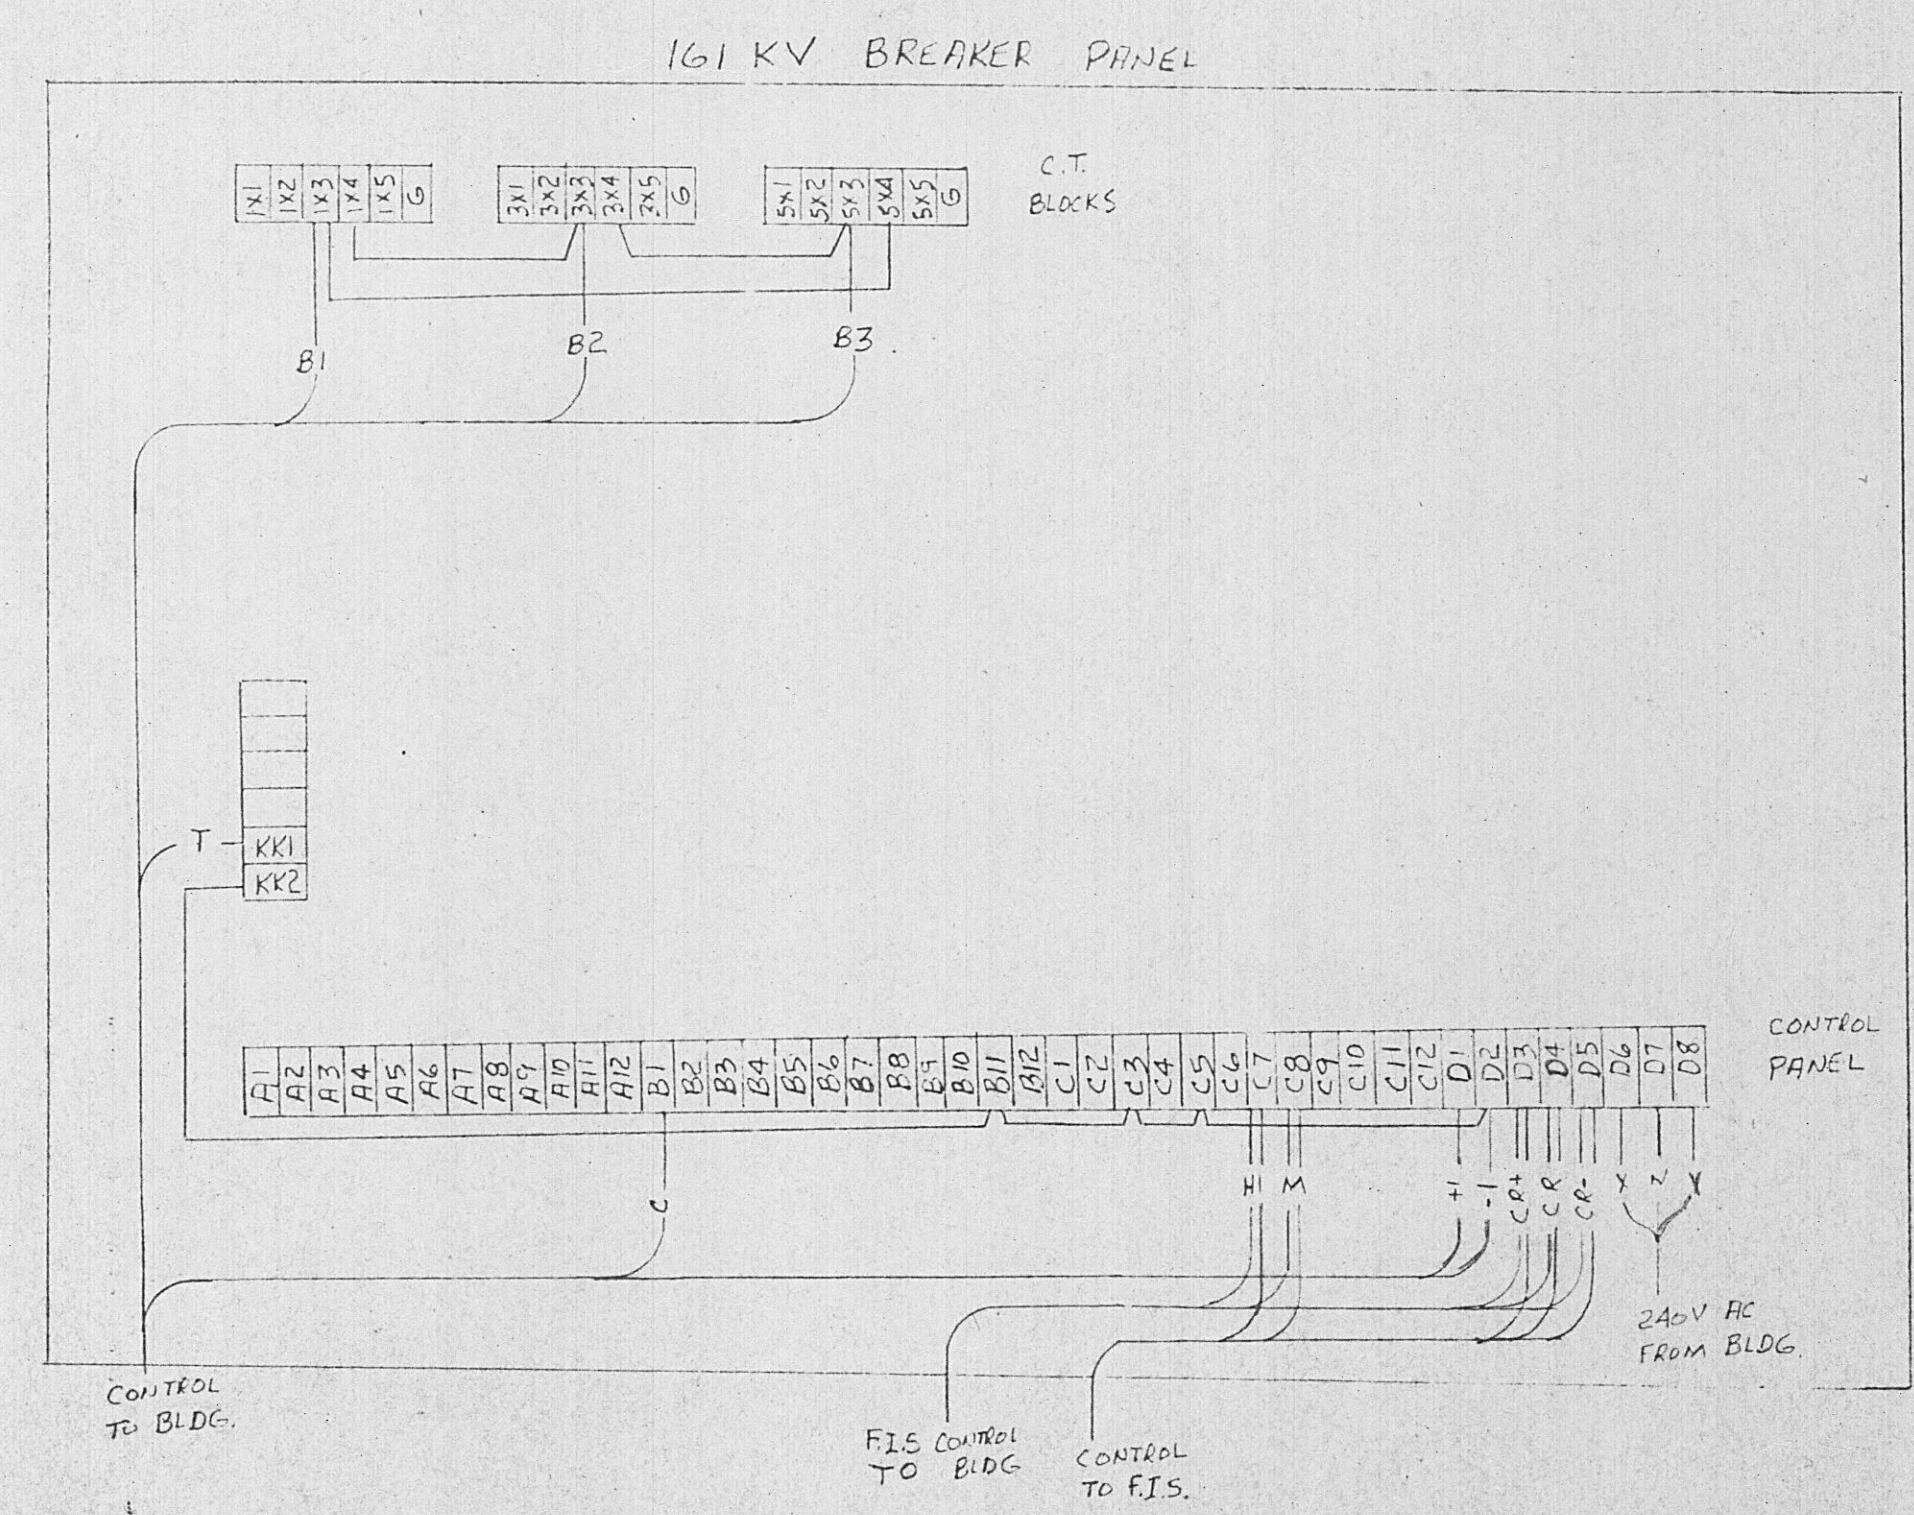
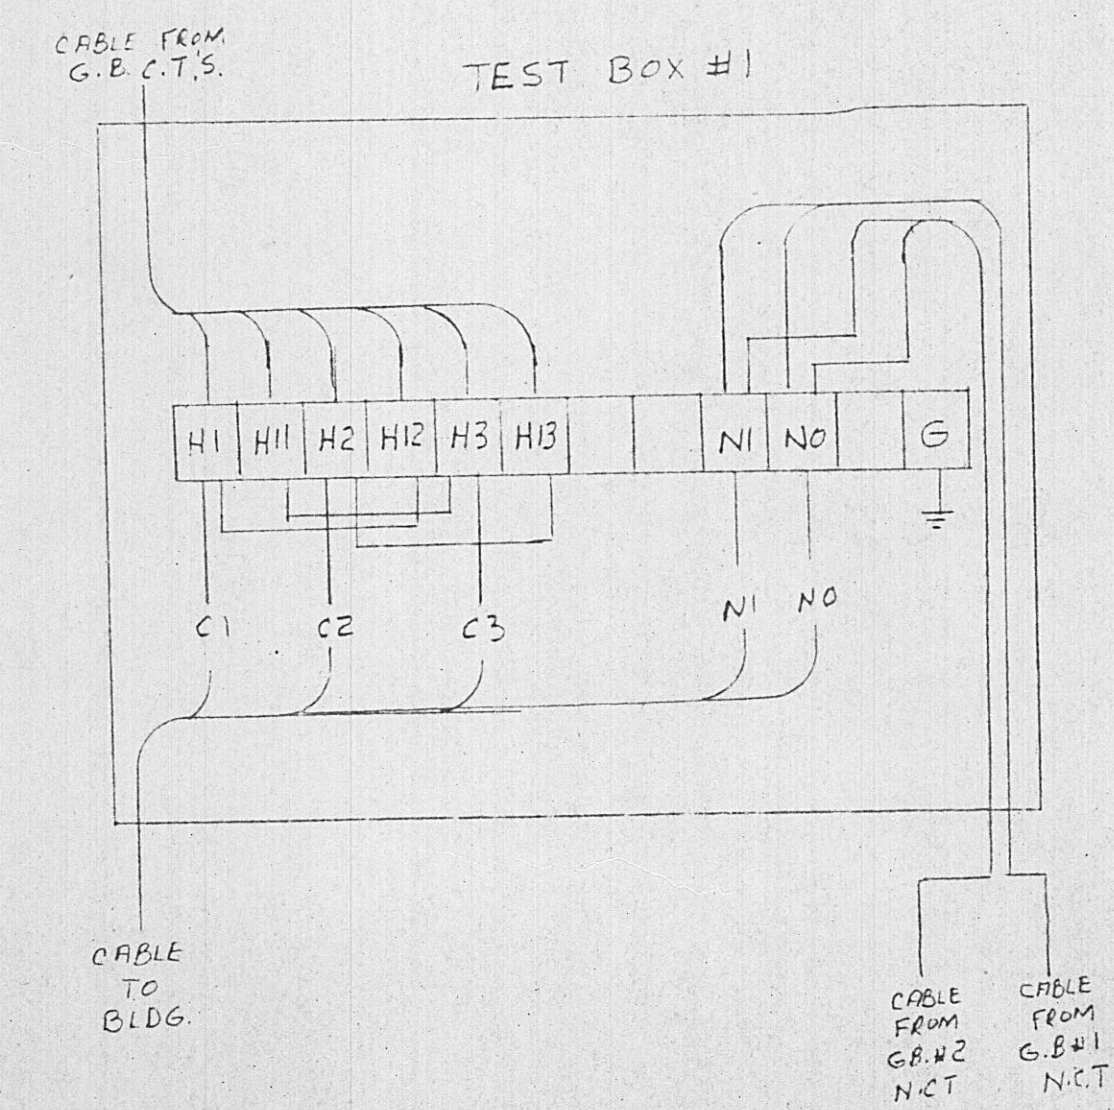
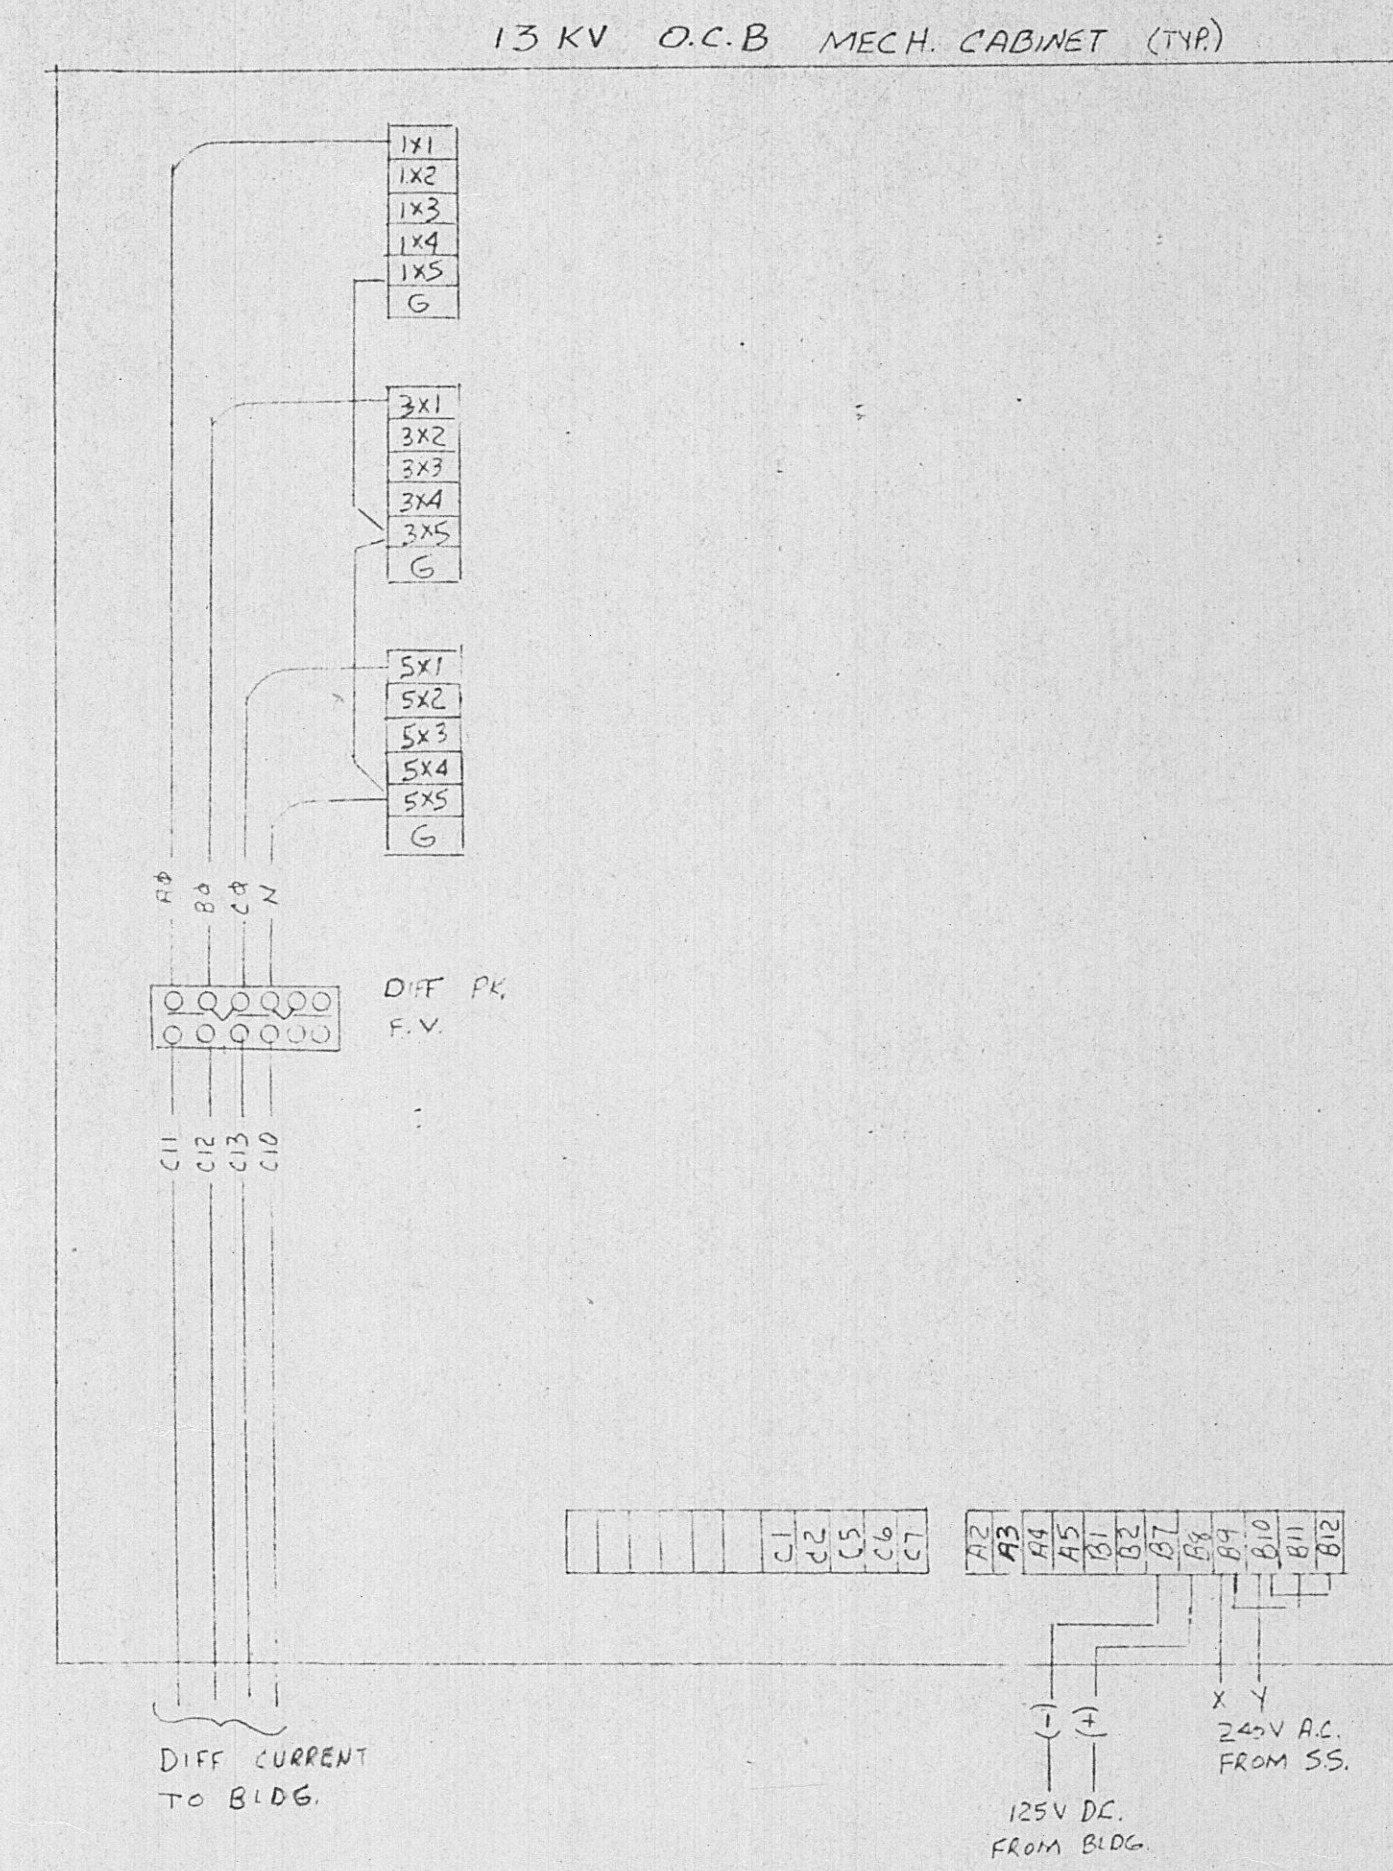
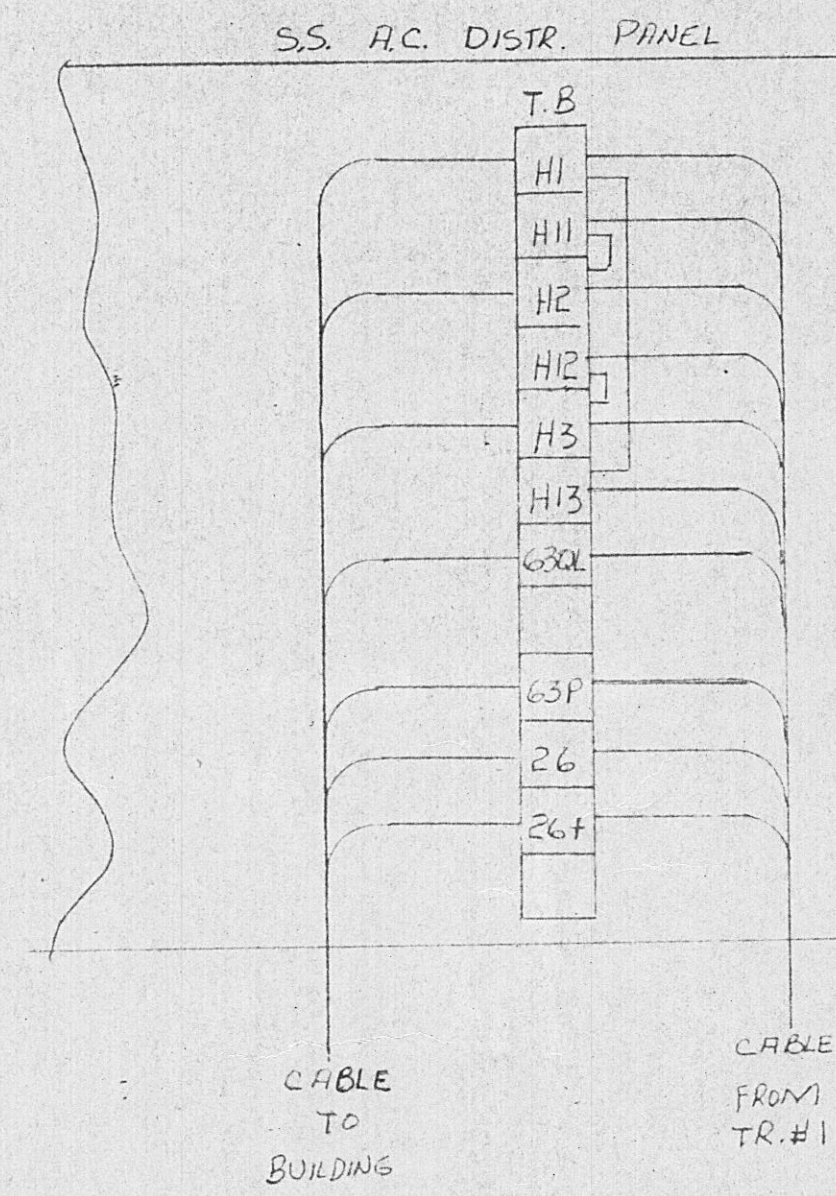



BLAIR ROAD SUBSTATION HARRIMAN UTILITY BOARD

CATALOGUE OF ELECTRICAL DRAWINGS

<u>SHEET NO.</u>	<u>DESCRIPTION</u>
1.	ONE LINE DIAGRAM
2.	THREE LINE DIAGRAM
3.	TVA # WL-8725, SH.1, ELEMENTARY DIAGRAMS, INTERNAL CONNECTIONS
4.	TVA # WL-8725, SH.2, ELEMENTARY DIAGRAM, TRANSF. BK. GND. SW. & DIFF. TRIPPING
5.	TVA # WL-8725, SH.3, ELEMENTARY DIAGRAM, BREAKER & ALARMS
6.	TVA # WL-8727, SH.1, SWITCHBOARD WIRING, PANEL 1
7.	TVA # WL-8727, SH.2, SWITCHBOARD WIRING, PANEL 2
8.	TVA # HC-25592, TRANSFORMER # 1 ACCESSORIES DIAGRAM
9.	CONNECTION DIAGRAMS

McWHORTER & FRANKLIN ENGINEERS
NASHVILLE, TENNESSEE

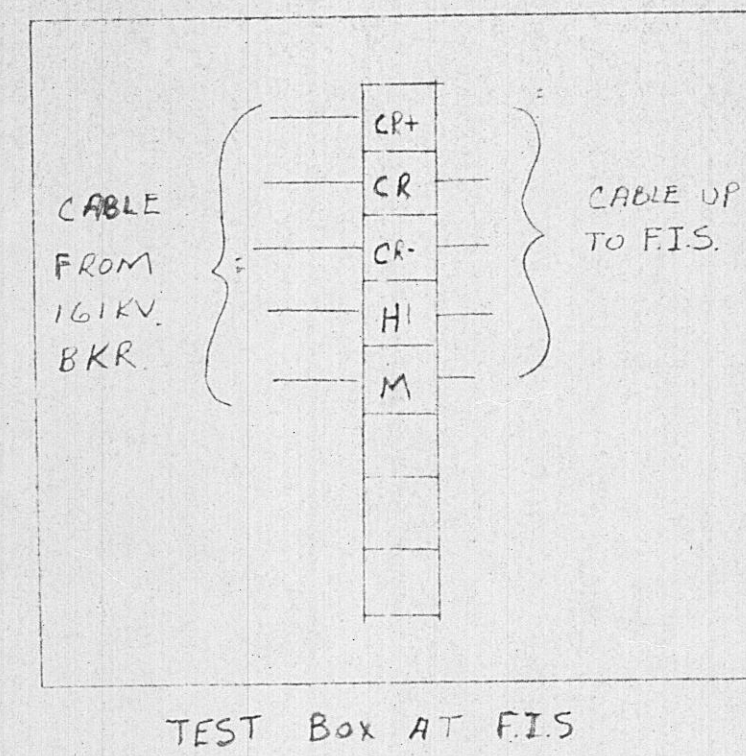

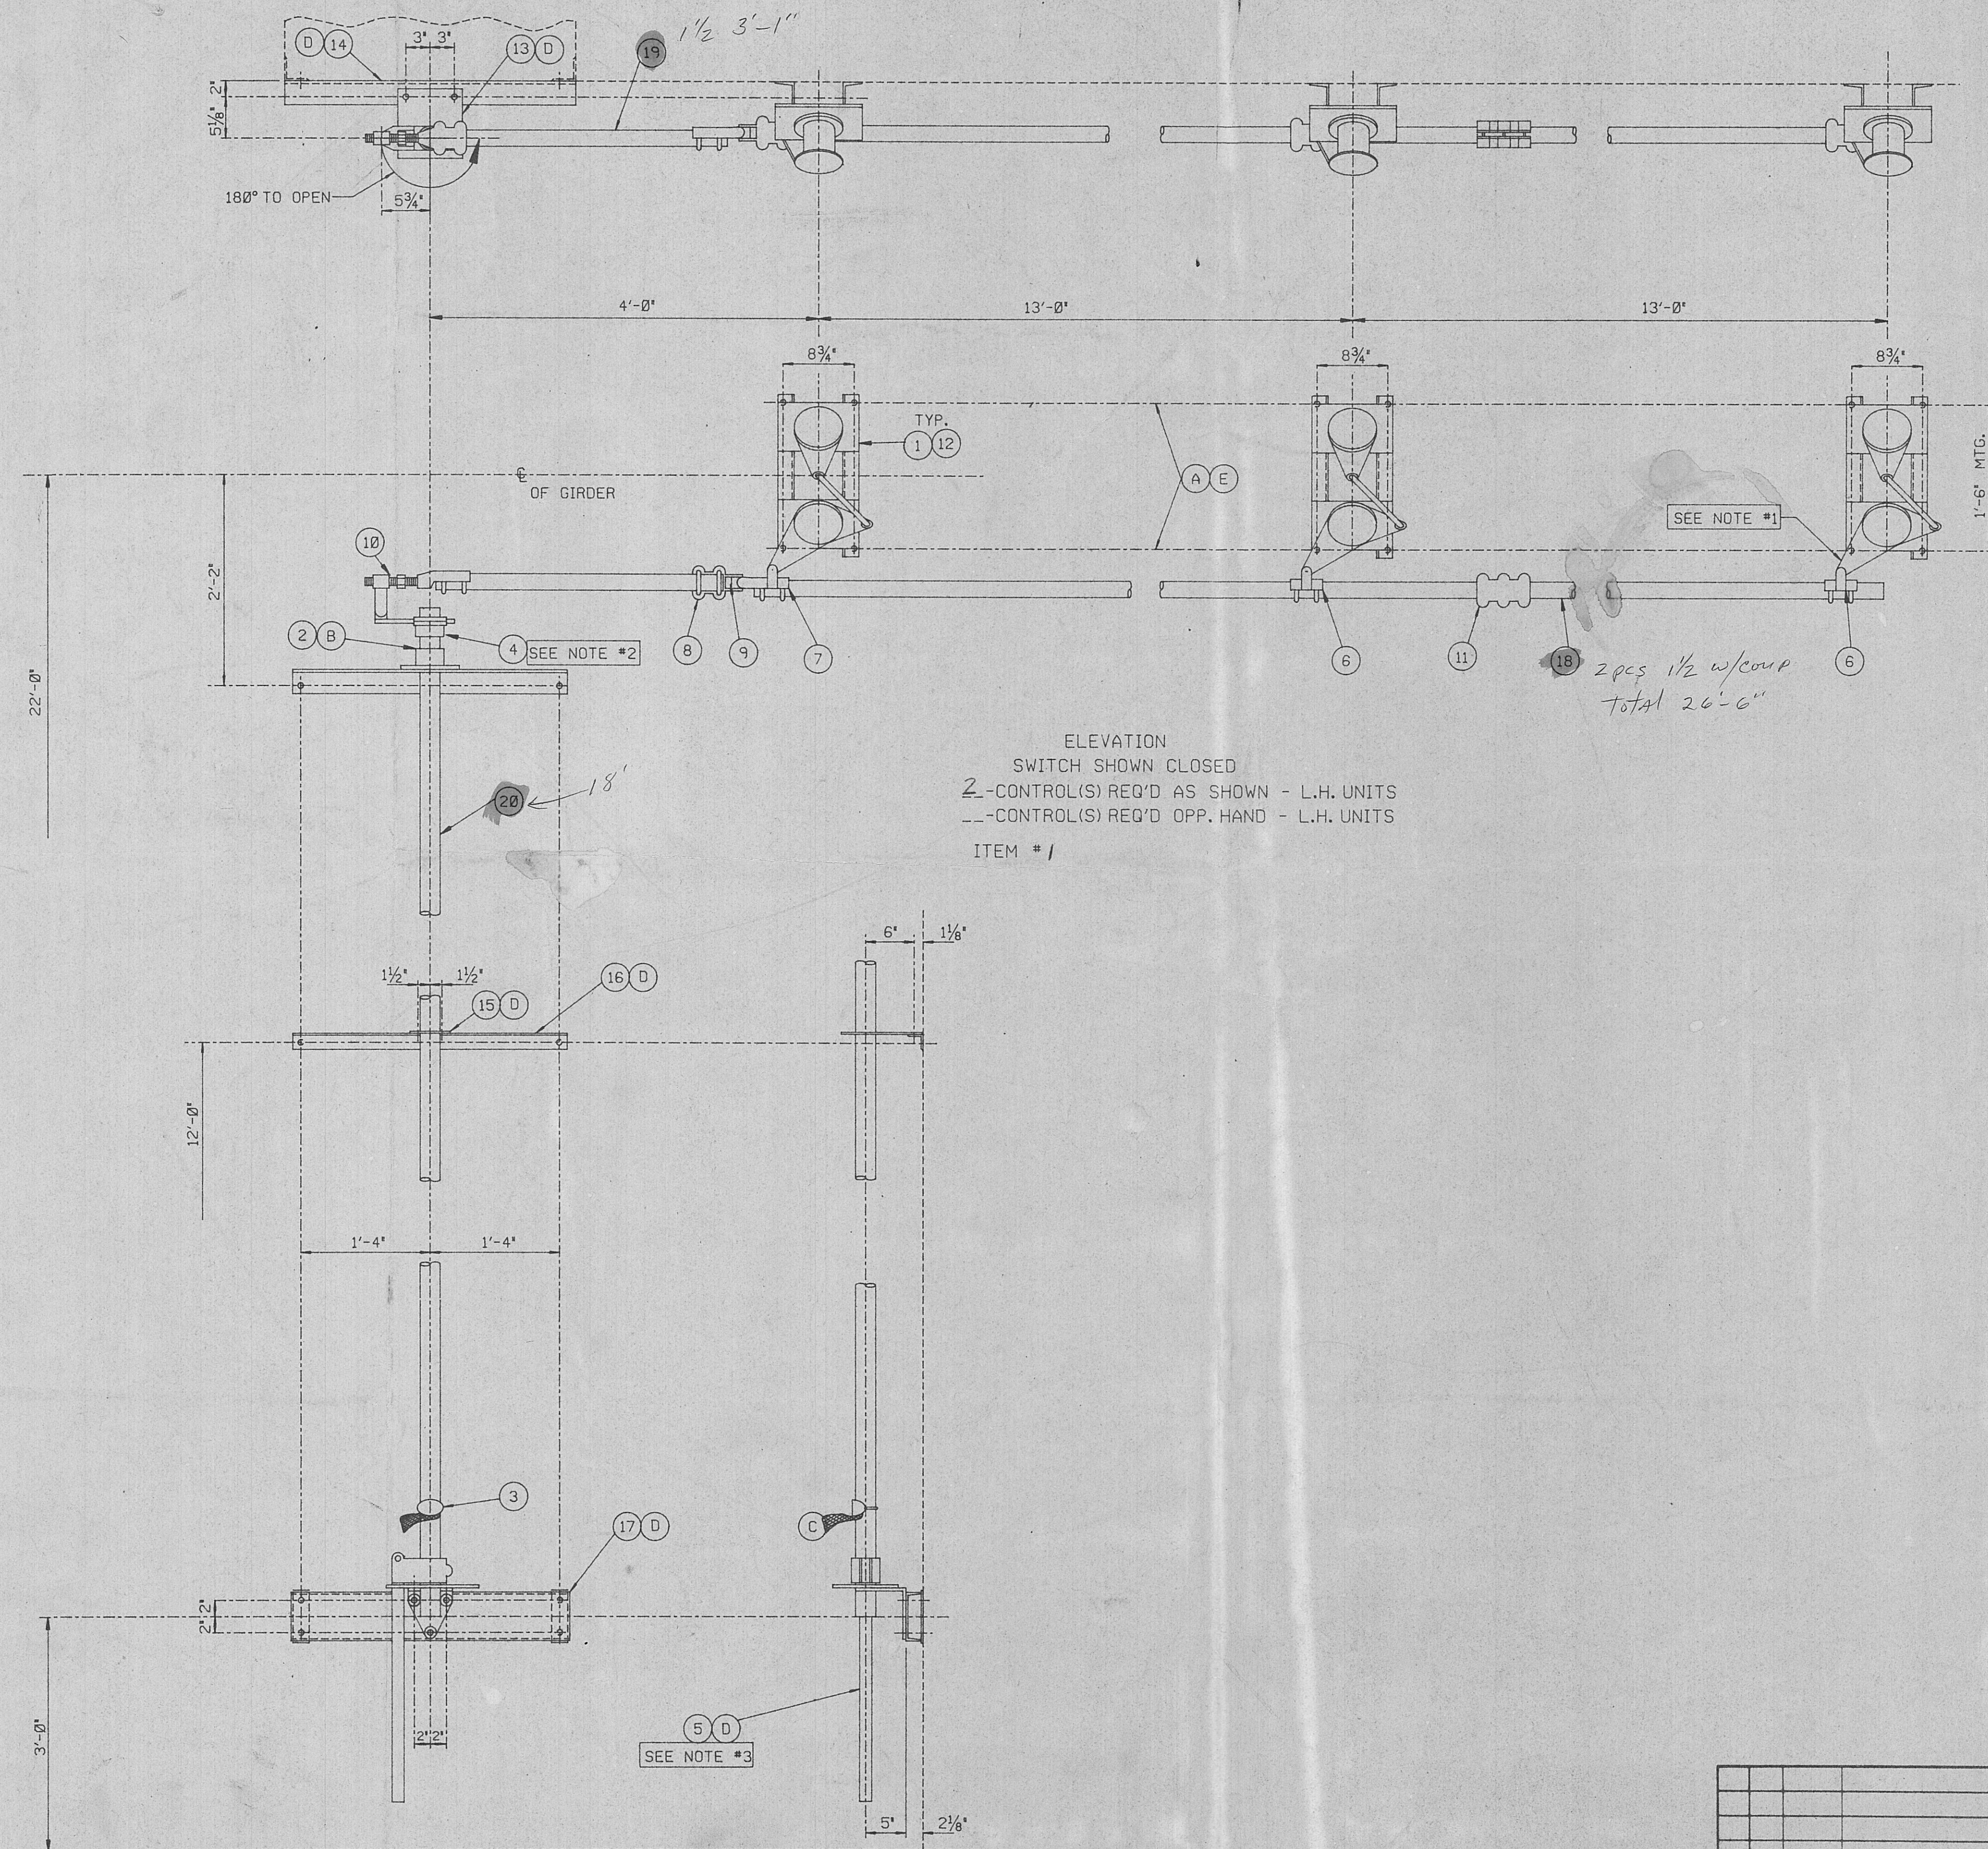

BILL OF MATERIAL		D-11257 SH.1		
ONE CONTROL		W.O. 44735		
ITEM	MARK	QTY.	DESCRIPTION	REF.
1	AGCH-5V	3	161 KV 1200 AMP SWITCH UNIT W/QUICK BREAK ARCING HORNS	C-2019 SH.128
2		1	BALL BRNG. ASS'Y	A-9023
3		1	GROUND SHUNT ASS'Y.	A-9027
4		1	ADJ. ARM ASS'Y.	A-9206
5		1	ROT. CONTROL	A-9261
6	601-38	2	1 1/2" IPS CLEVIS	
7	601-145	1	1 1/2" IPS CLEVIS	
8	601-118	1	1 1/2" IPS CLEVIS	
9	601-54	1	UNIVERSAL KNUCKLE	
10	601-80/160	1	1 1/2" IPS THD. CLEVIS ASS'Y.	B-5233 SH.35
11	601-23	1	1 1/2" IPS COUPLER	
12	MK-6697-1	6	SWITCH BASE	B-6697
13	MK-6697-2	1	BRNG. PLATE	B-6697
14	MK-6697-3	1	BRNG. PLATE SUPPORT	B-6697
15	MK-6697-4	1	PIPE GUIDE	B-6697
16	MK-6697-5	1	PIPE GUIDE SUPPORT	B-6697
17	MK-6697-6	1	CONTROL SUPPORT	B-6697
18		1	2 PCS. 1 1/2" STD. GALV. PIPE X 26'-6" TOT LGTH.	
19		1	1 1/2" STD. GALV. PIPE X 3'-1"	
20		1	2" STD. GALV. PIPE X 18'-0"	
A		12	5/8" X 2" GALV.H.H.BOLT,H.N.,L.W.	
B		2	1/2" X 1 1/2" GALV.H.H.BOLT,H.N.,L.W.	
C		1	5/8" X 3" GALV.H.H.BOLT,H.N.,L.W.	
D		15	5/8" X 1 1/2" GALV.H.H.BOLT,H.N.,L.W.	
E		12	5/8" GALV. BEVEL WASHERS	

NOTES:

- *1 Do not change stop bolts on main switch bearings. The tie wires should be left on all switch units until all clevises, reach rods, and arms have been secured, then removed.
- *2 Adjustment should be made on this arm to assure full opening and closing of each switch unit. The dimension shown on the arm is a trial dimension, as the arm may need to be lengthened or shortened to completely open and close the switch, due to differences in specific applications.
- *3 Angular adjustment should be made as desired by moving the stop plates on the control handle, or stop bolts on the gear box control handle when furnished.




USCO Power Equipment Corporation

Post Office Box 10023 • Birmingham, Alabama 35202-0023
Telephone (205) 592-7241 • Facsimile (205) 592-0470

REFERENCES		CONTROL DETAILS		DRAWN: 7-21-94 TLR	
SKETCH		TYPE "AGCH-5V" 161 KV 1200 AMP HARRIMAN UTILITY BOARD		TRACED:	
				CHECKED:	
				SH. REV.	
				D-11257	
				1	

BY	NO.	DATE	REVISION

W.O. 44735 P.O. 12108 APPROVED:

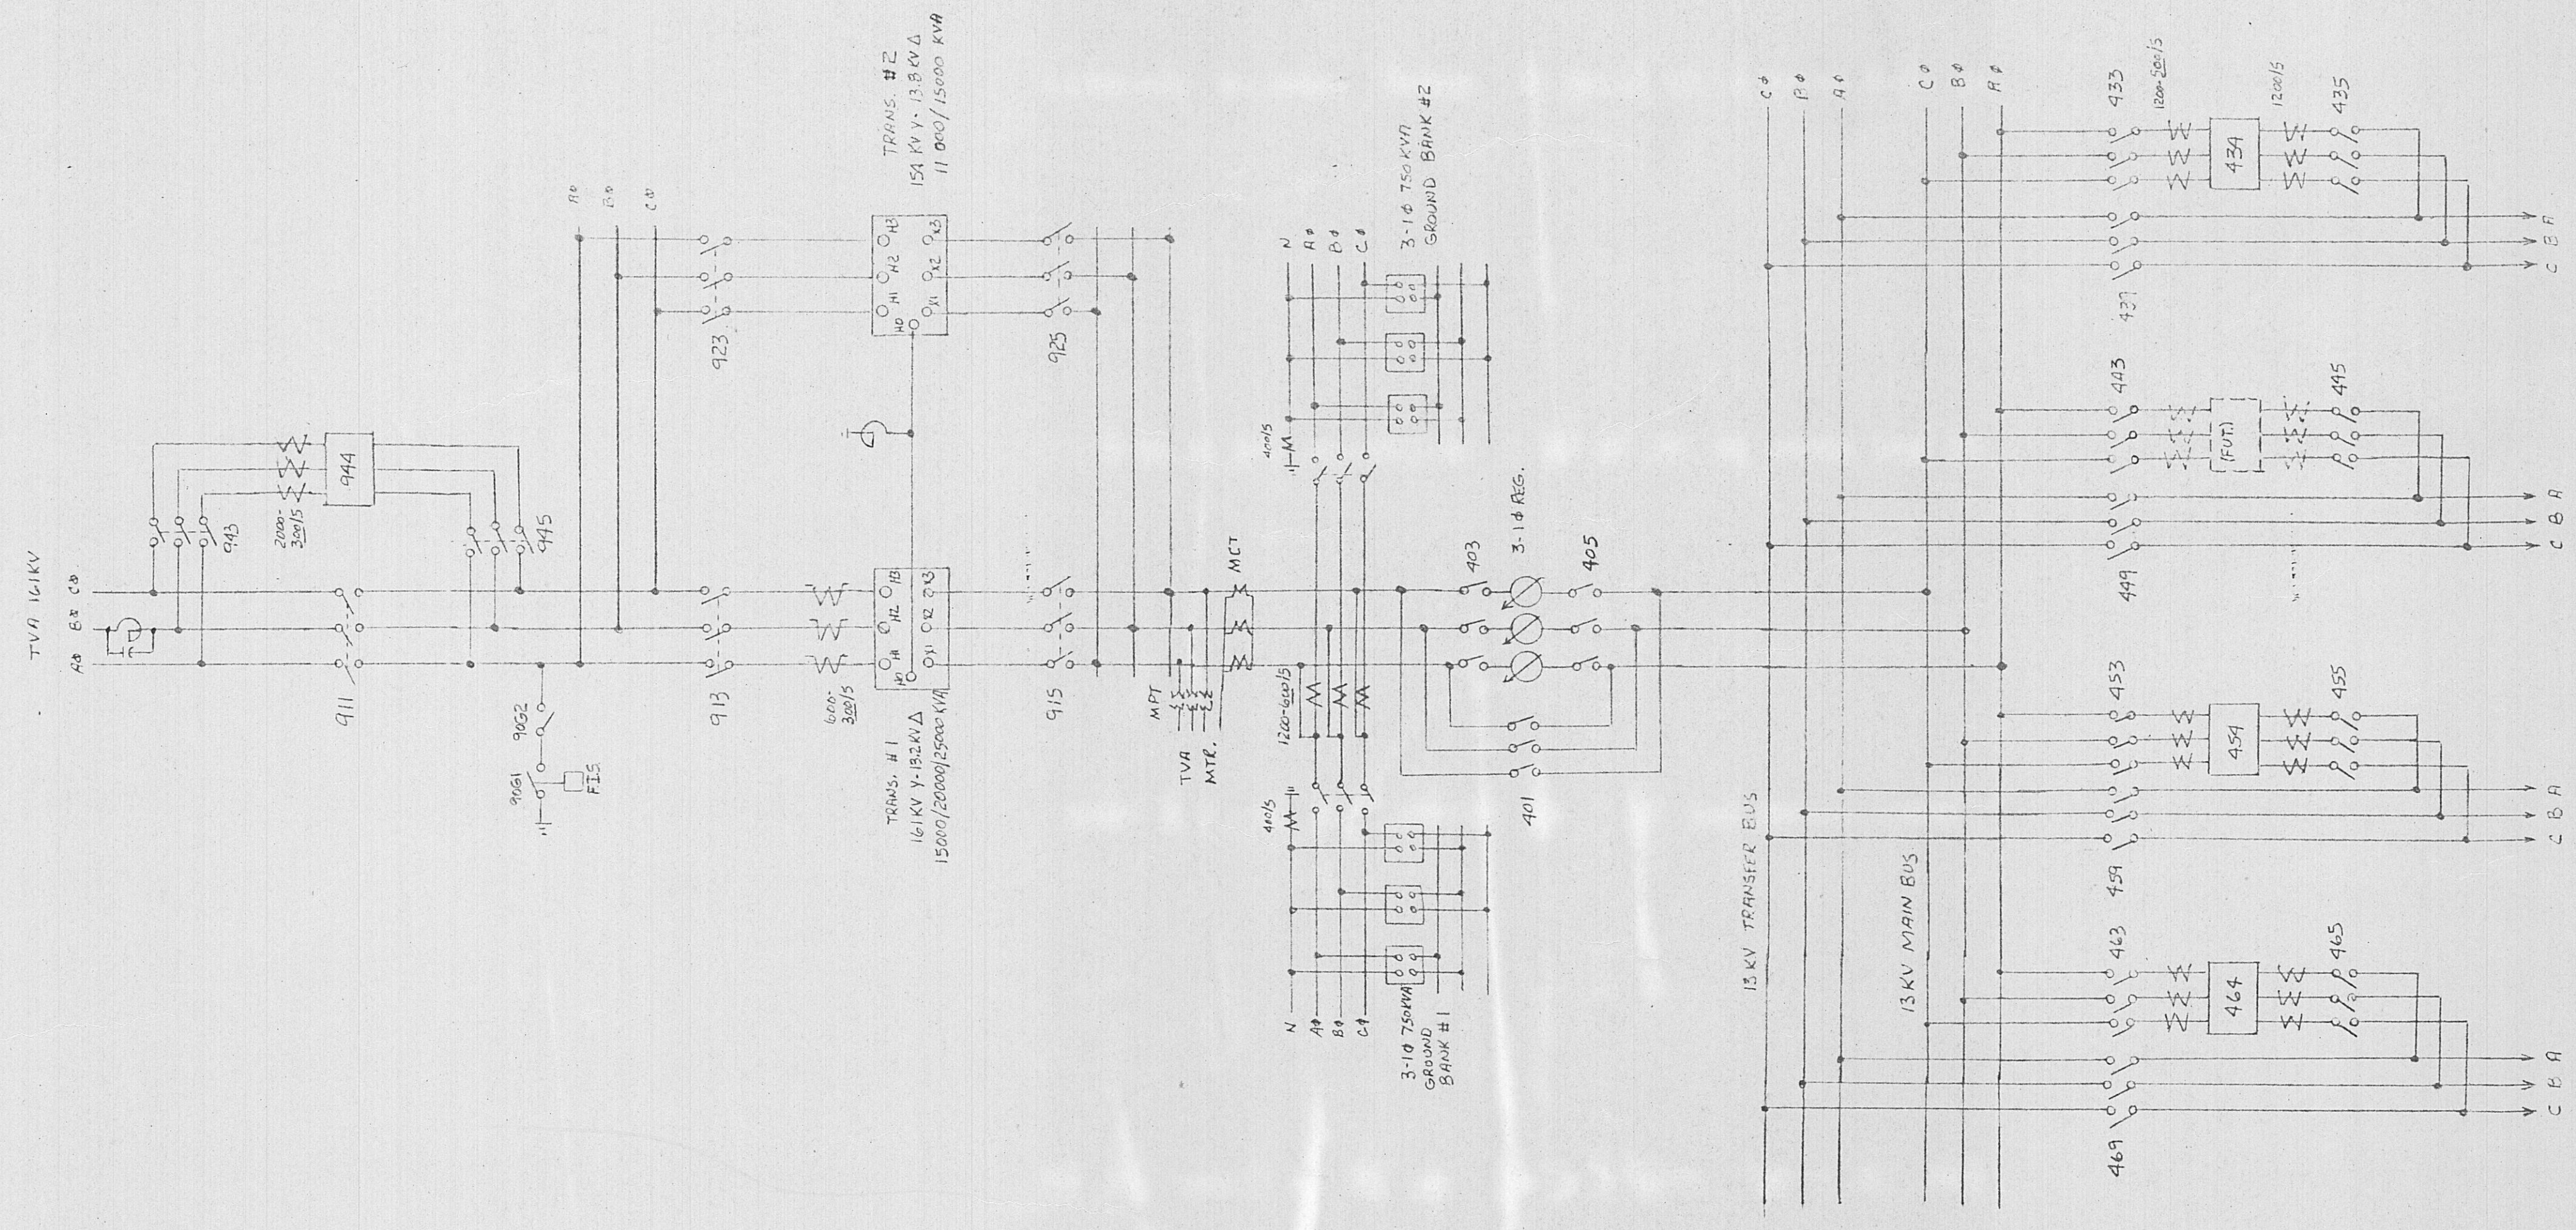











HARRIMAN UTILITY BOARD
BLAIR ROAD SUBSTATION
THREE LINE DIAGRAM

DATE: 4-6-95
DRAWN:
SCALE:

McWHORTER & FRANKLIN ENGINEERS
NASHVILLE, TENNESSEE
2117 FRANKLIN ROAD - 37204 TEL. (615)298-3338

DATE REVISIONS

5228-7M

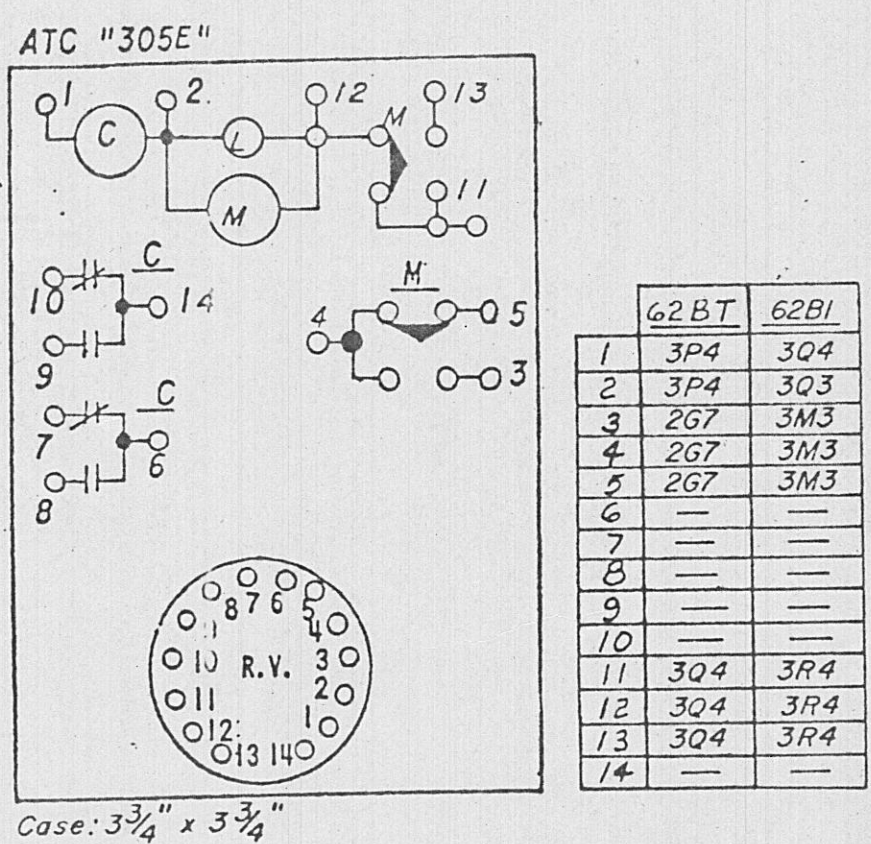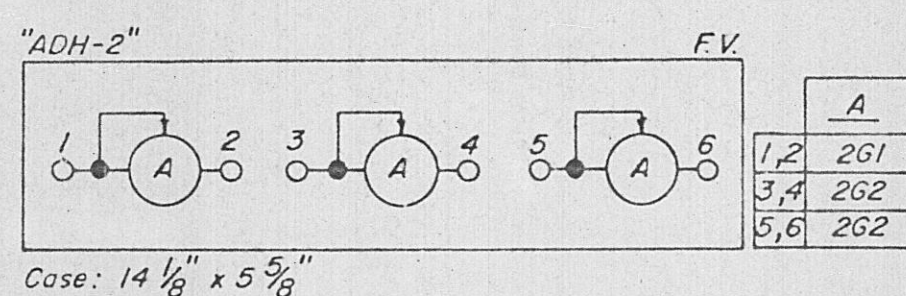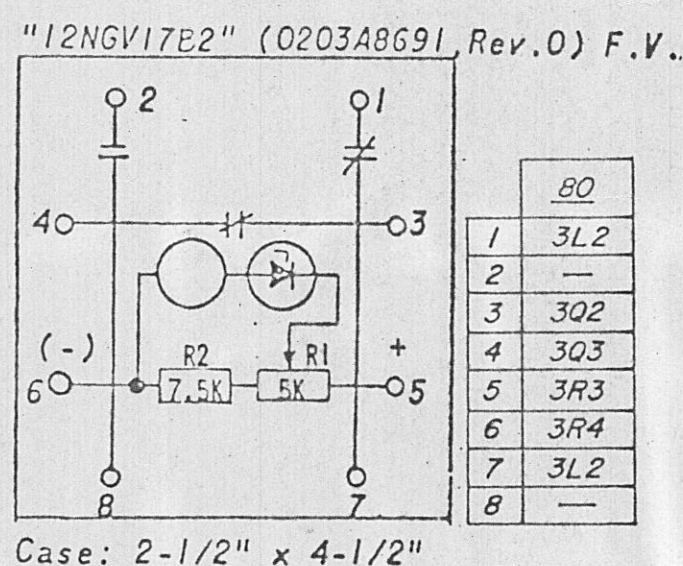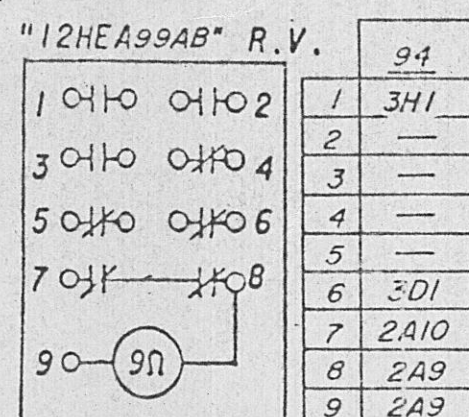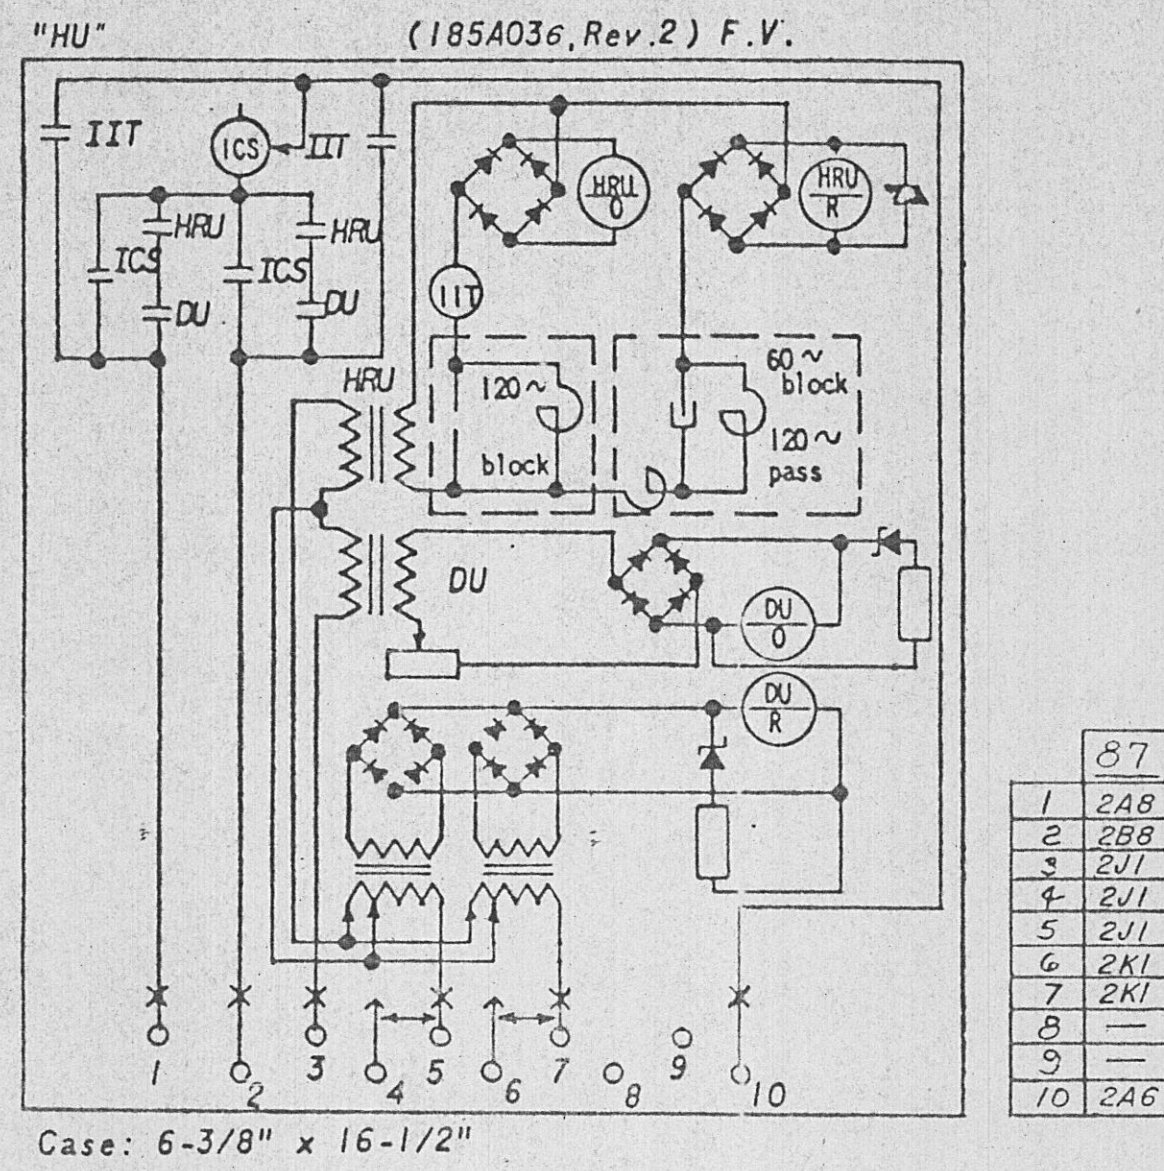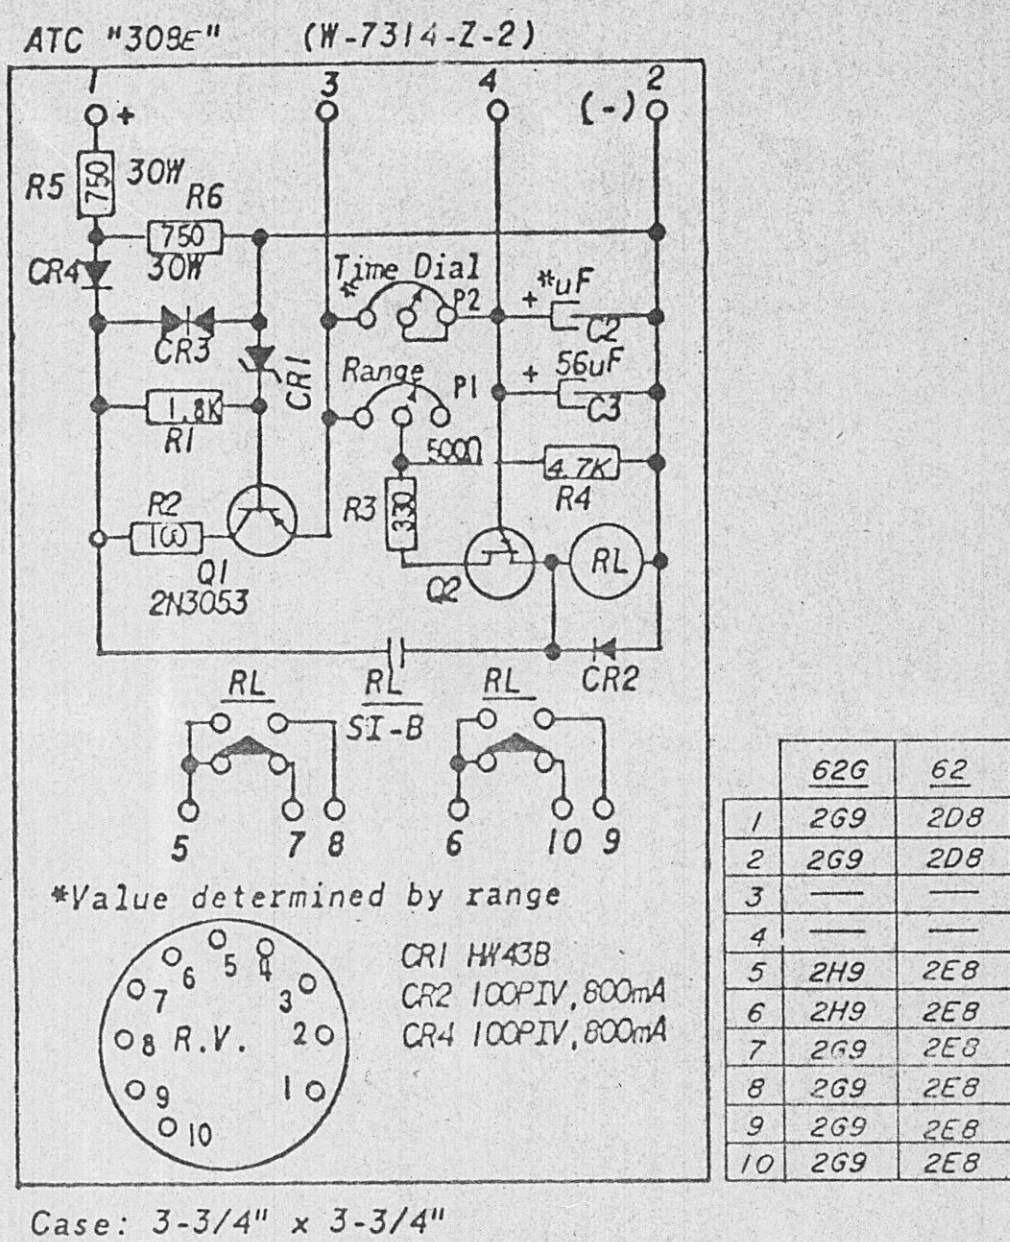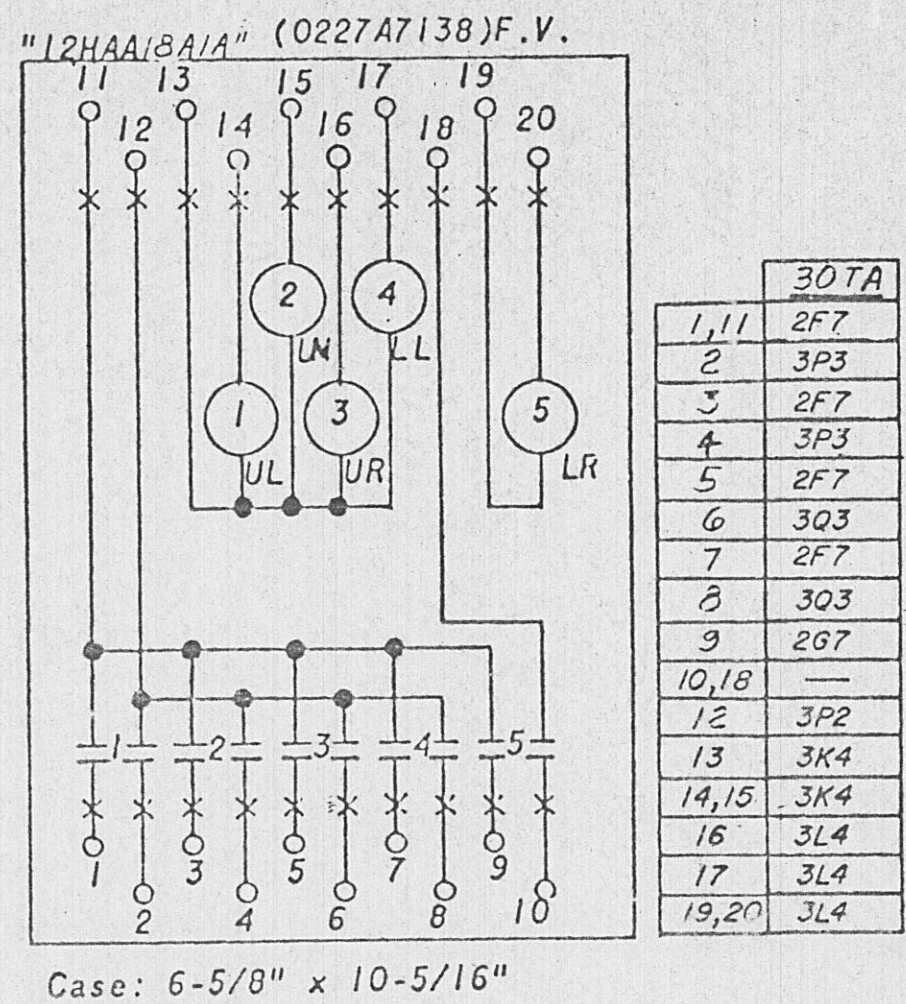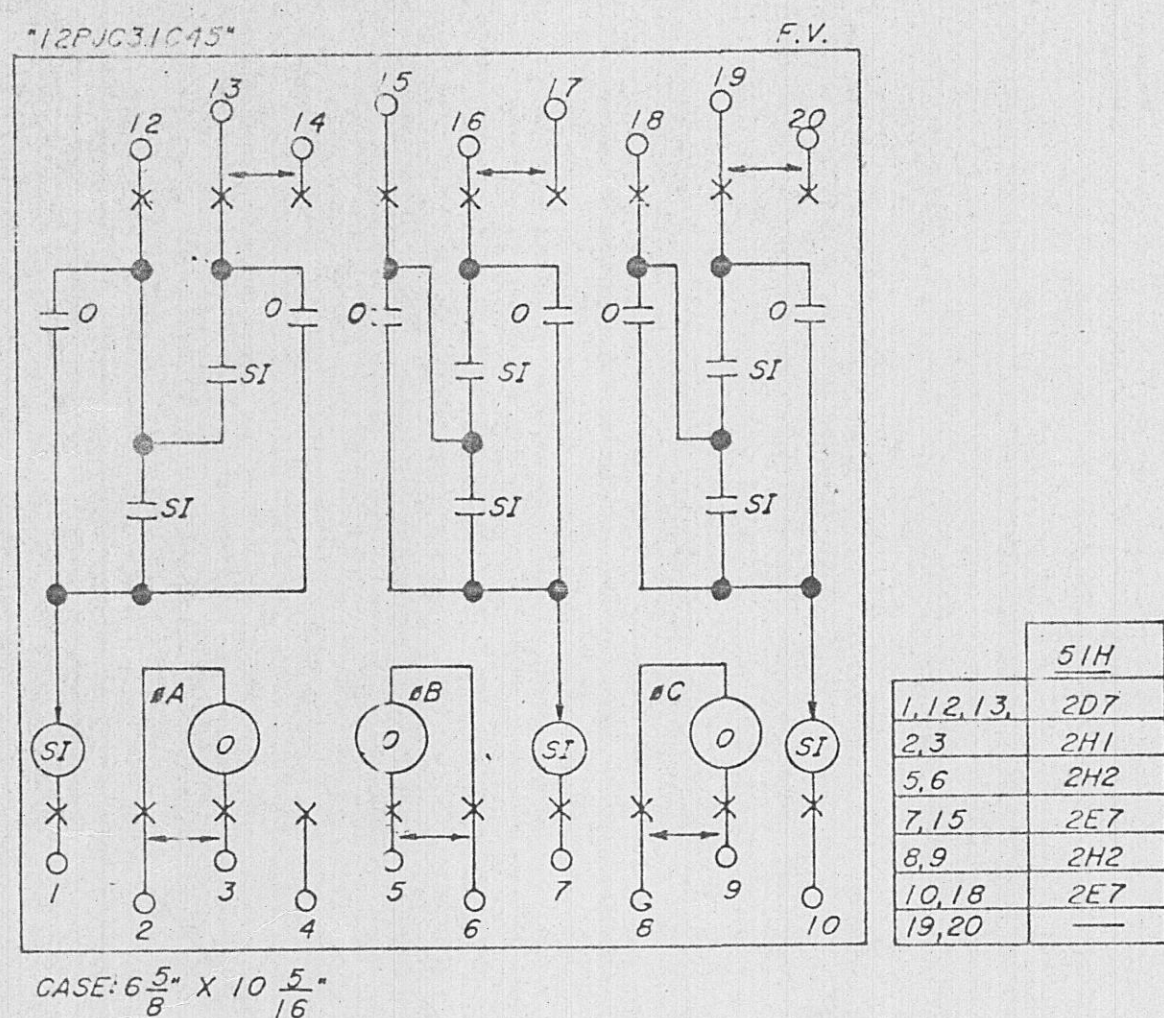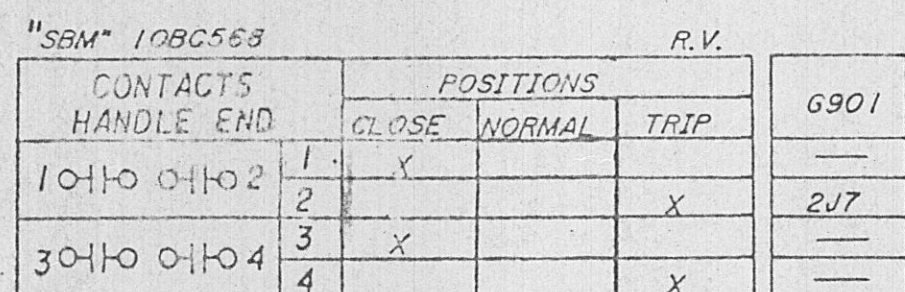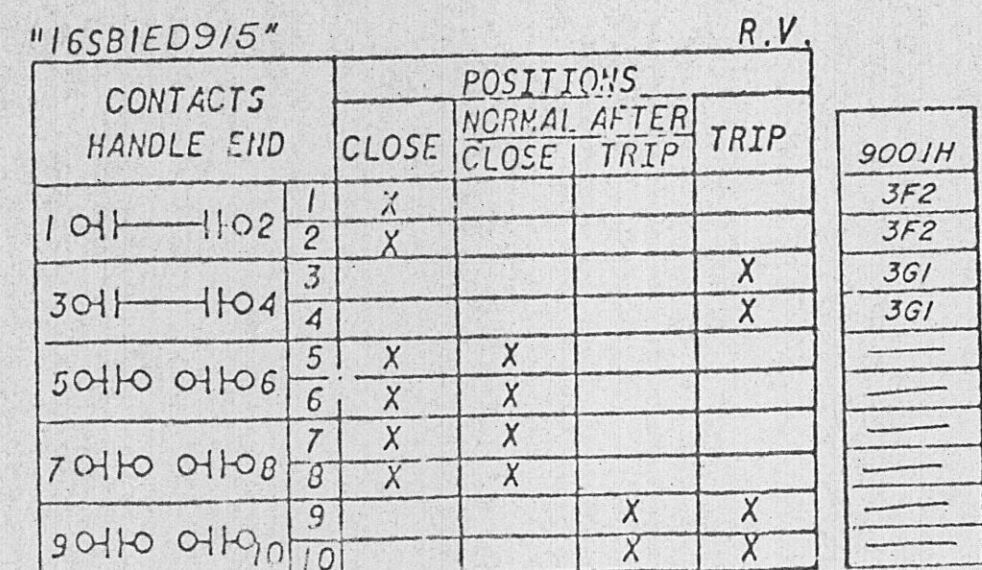

REFERENCES:
Single Line Diagram WL-8723
Switchboard Front View WL-8726
Switchboard Wiring Rear View WL-8727

MARKED FOR BLAIR ROAD SUB									
REV. NO.	DATE	WORK ORDER	DSGN	DRWN	CHKD	SUPV.	SUBM.	MF	
1	4-17-95								
DSGN	JA	SUPV.	W.S.						
DRWN	SB/DLP								
CHKD	JS								


TENNESSEE VALLEY AUTHORITY
DIVISION OF TRANSMISSION PLANNING AND ENGINEERING
HARRIMAN UTILITY BOARD
BLAIR ROAD SUBSTATION-161KV
ELEMENTARY DIAGRAM
INTERNAL CONNECTIONS

DATE	SUBMITTED	APPROVED	SHEET	OF	SHEETS
9/1/82	3/1/82		1	3	
SCALE	CLASS. CODE	MICROFILMED			
NONE	D502				

STATION NO. 5296

WL-8725


SHEET
3

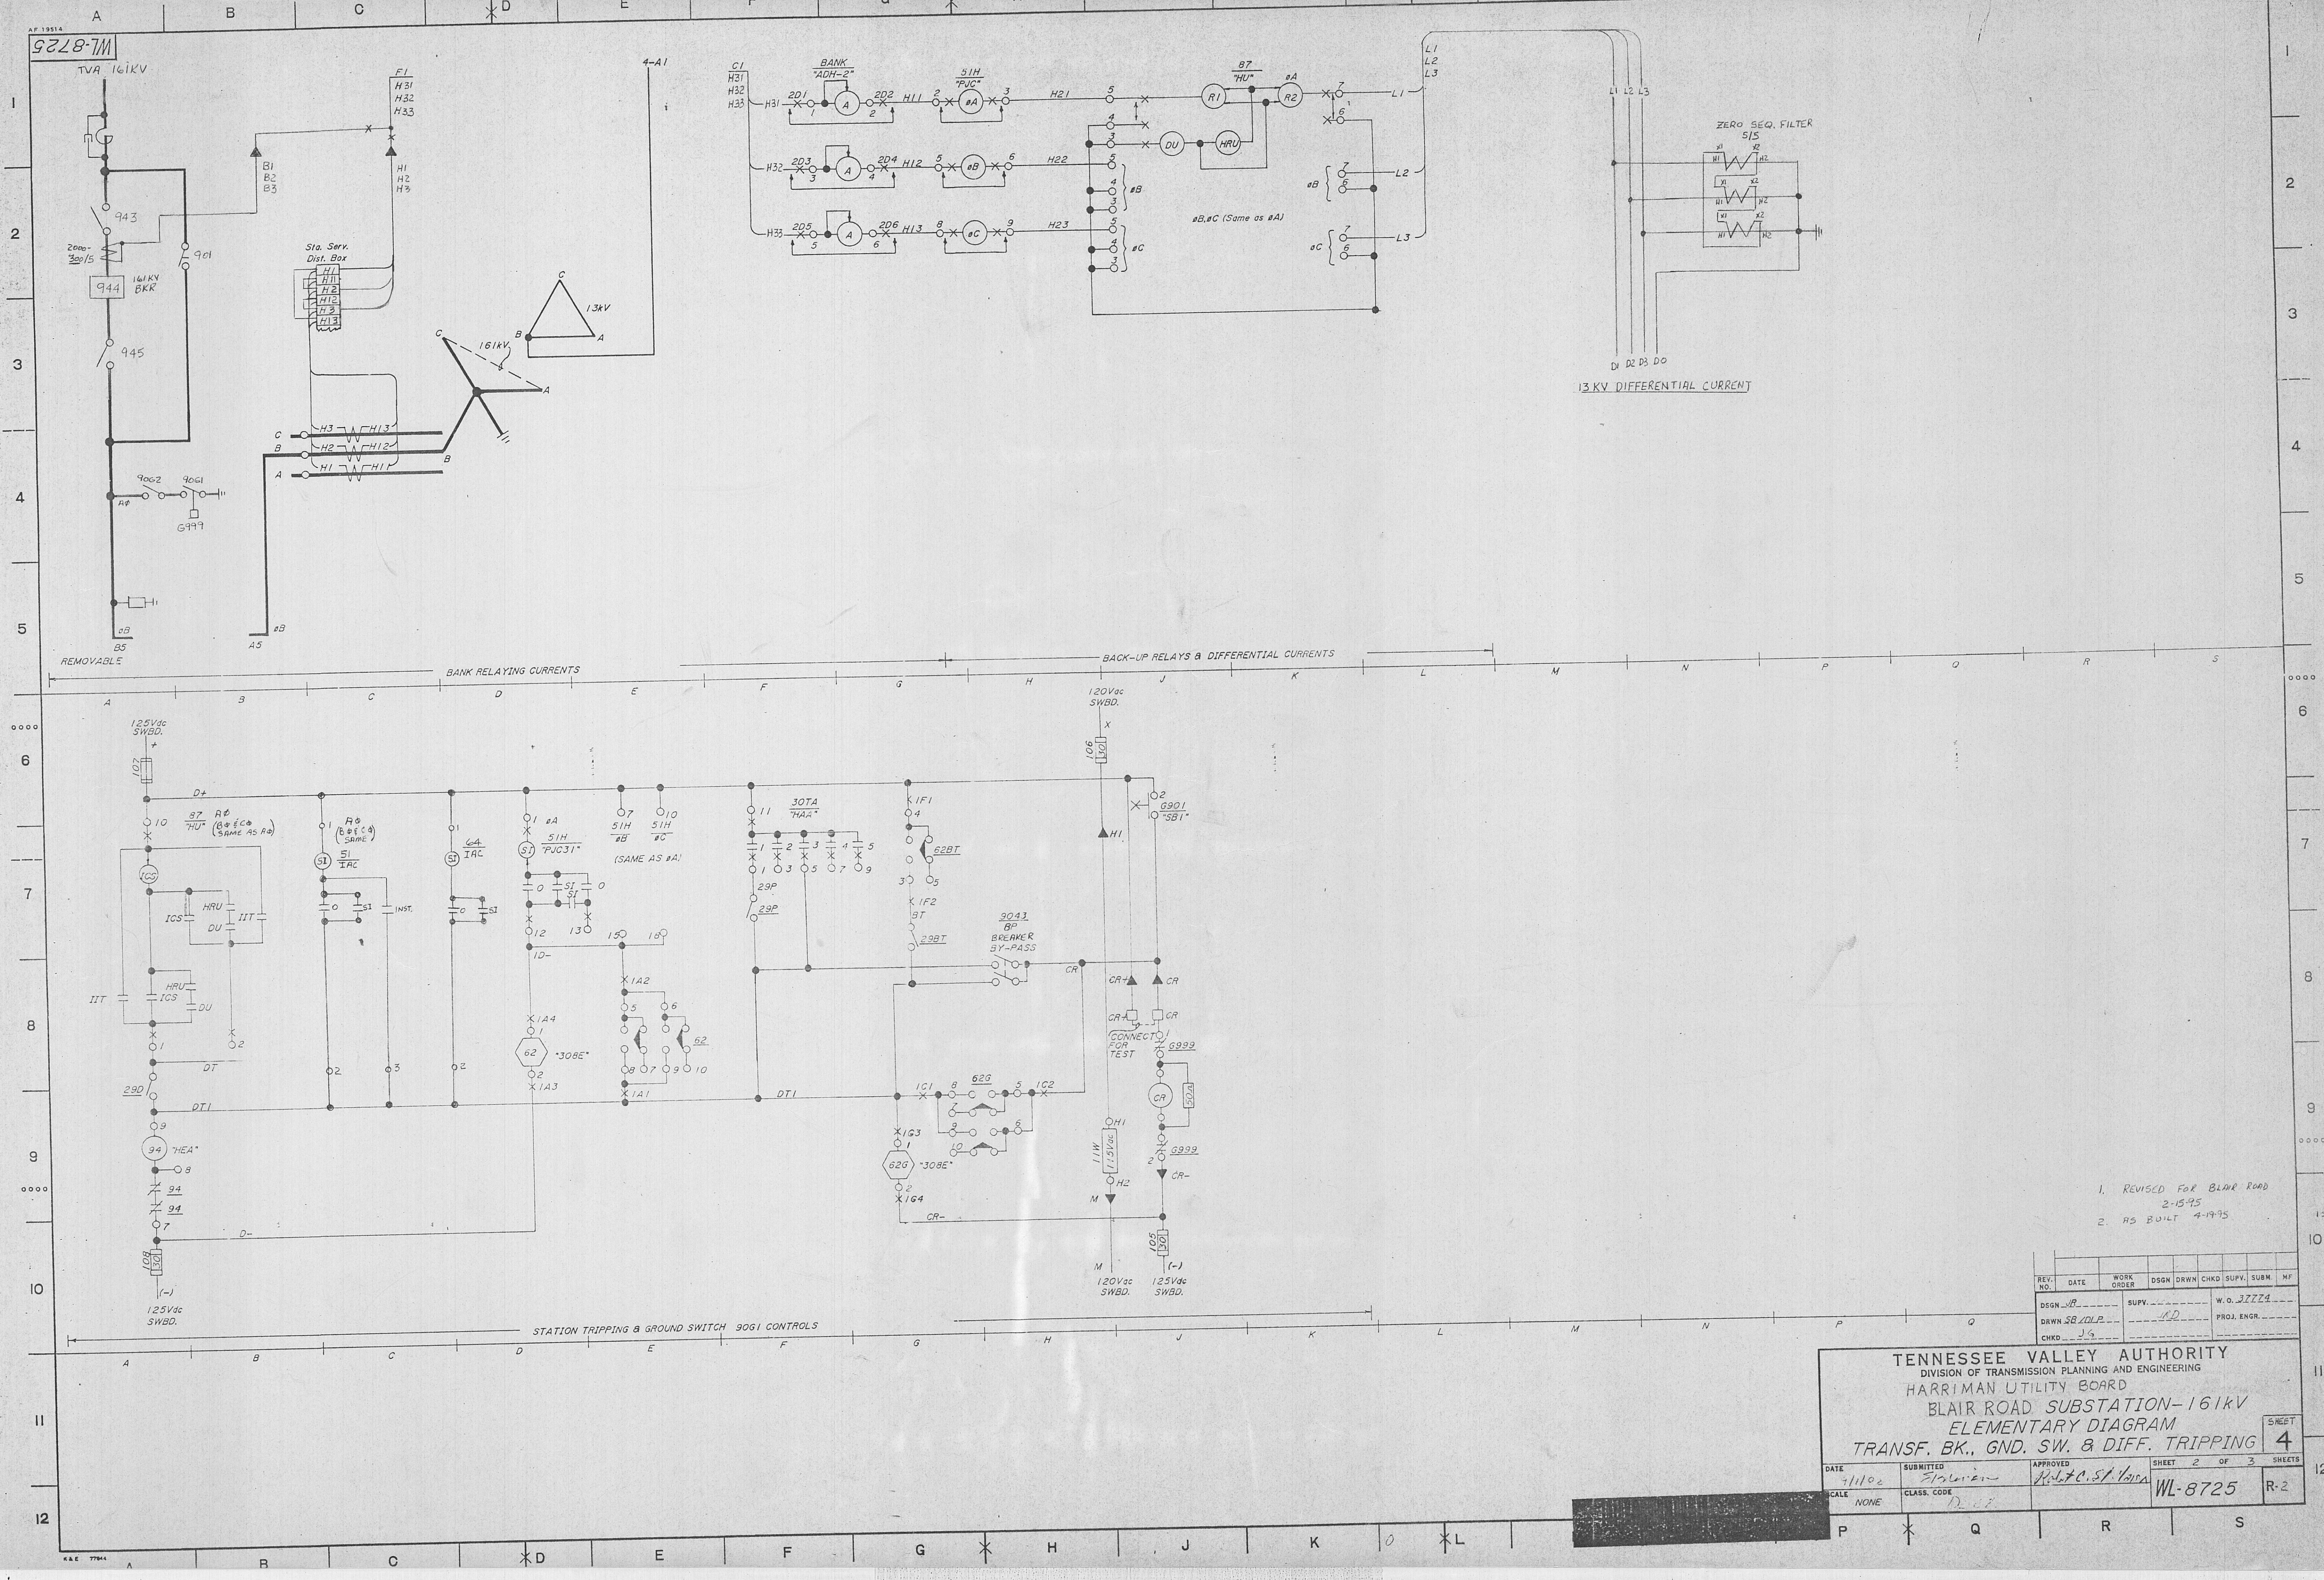

- 1. REVISED FOR BLAIR ROAD 2-15-95
- 2. AS BUILT 4-19-95

REV. NO.	DATE	WORK ORDER	DSGN	DRWN	CHKD	SUPV.	SUBM.	MF
1	7/1/02		W.O. 37774					
2	7/1/02		W.O. 37774					
3	7/1/02		W.O. 37774					

TENNESSEE VALLEY AUTHORITY			
DIVISION OF TRANSMISSION PLANNING AND ENGINEERING			
HARRIMAN UTILITY BOARD			
BLAIR ROAD SUBSTATION-161KV			
ELEMENTARY DIAGRAM			
TRANSF. BK., GND. SW. & DIFF. TRIPPING			
DATE	SUBMITTED	APPROVED	SHEET 2 OF 3 SHEETS
7/1/02	7/1/02	7/1/02	4
SCALE	CLASS. CODE		WL-8725 R-2
NONE	12.00		

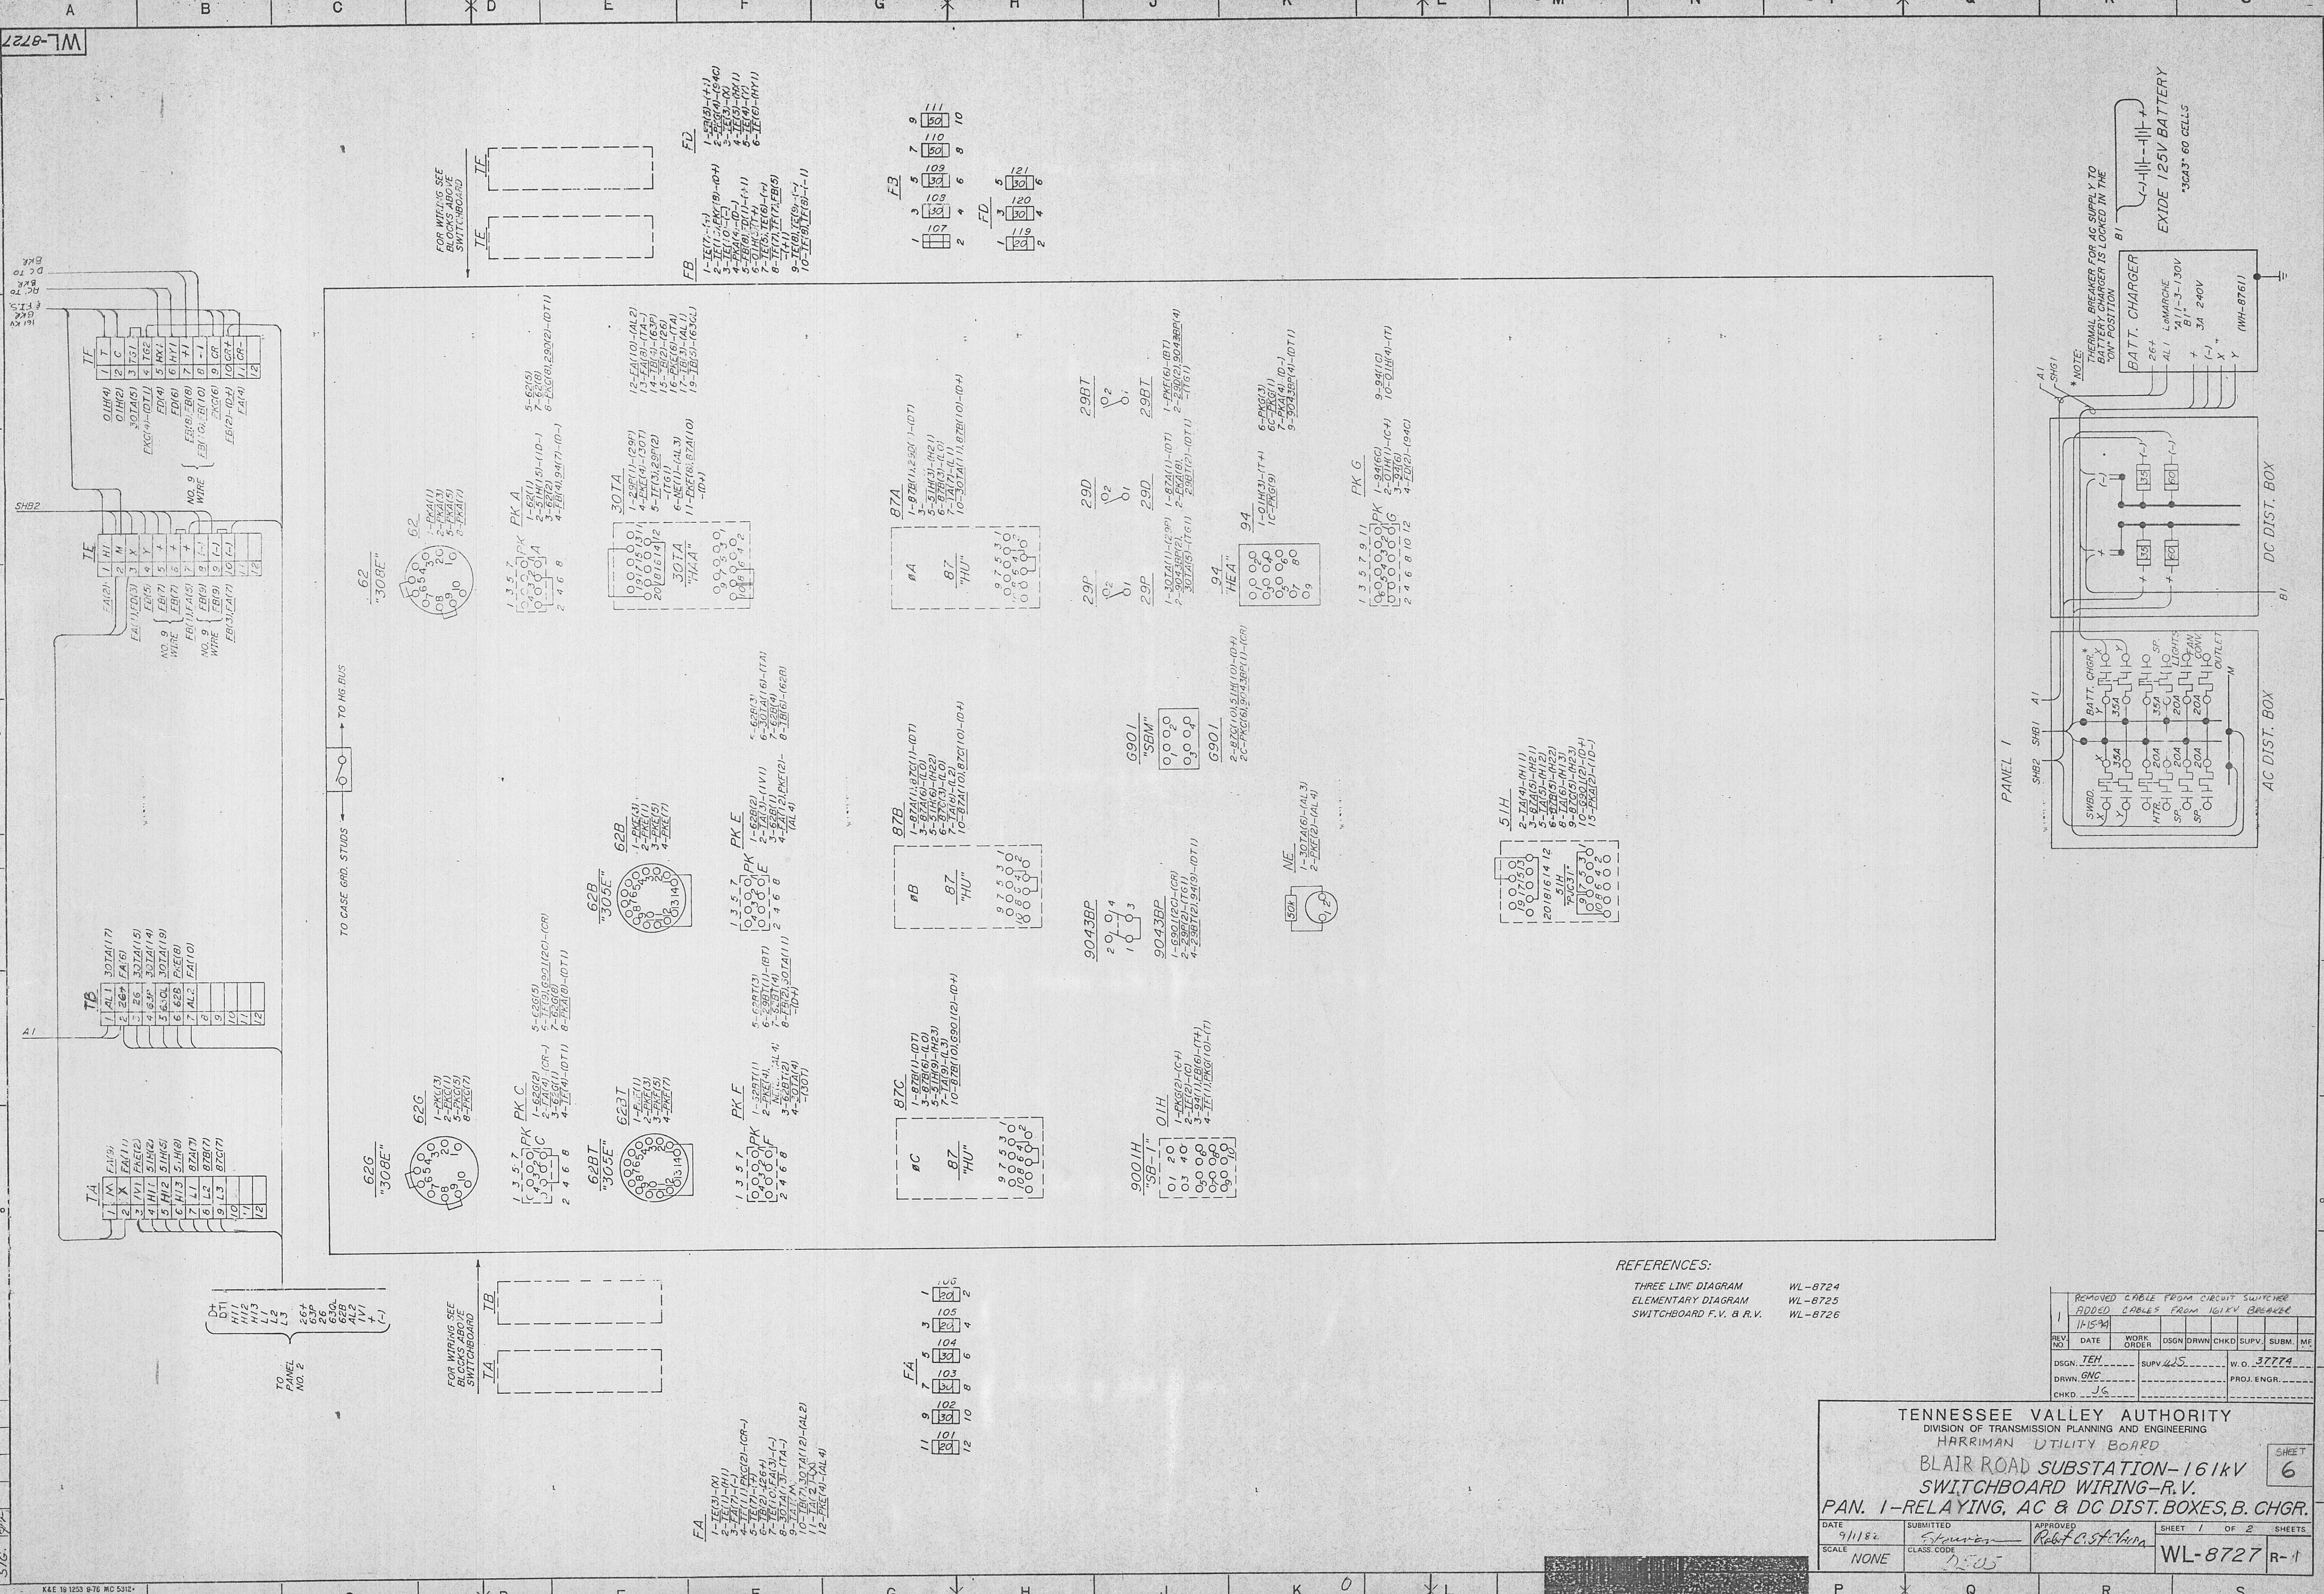

REFERENCES:

THREE LINE DIAGRAM
ELEMENTARY DIAGRAM
SWITCHBOARD F.V. & R.V.

WL-8724
WL-8725
WL-8726



1	REMOVED CABLE FROM CIRCUIT SWITCHER							
	ADDED CABLES FROM 161KV BREAKER							
	11/15/91							
REV. NO.	DATE	WORK ORDER	DSGN	DRWN	CHKD	SUPV.	SUBM.	MF
	TEH		SUPV. JLS			W. O. 37774		
	GNC					PROJ. ENGR.		
	JG							

TENNESSEE VALLEY AUTHORITY
DIVISION OF TRANSMISSION PLANNING AND ENGINEERING
HARRIMAN UTILITY BOARD

BLAIR ROAD SUBSTATION-161kV
SWITCHBOARD WIRING-R.V.
PAN. 1-RELAYING, AC & DC DIST. BOXES, B. CHGR.

DATE 9/1/82	SUBMITTED <i>Sturman</i>	APPROVED <i>Robert C. St. John</i>	SHEET 1 OF 2 SHEETS	
SCALE NONE	CLASS CODE 7-25		WL-8727	R-1

HC-25592

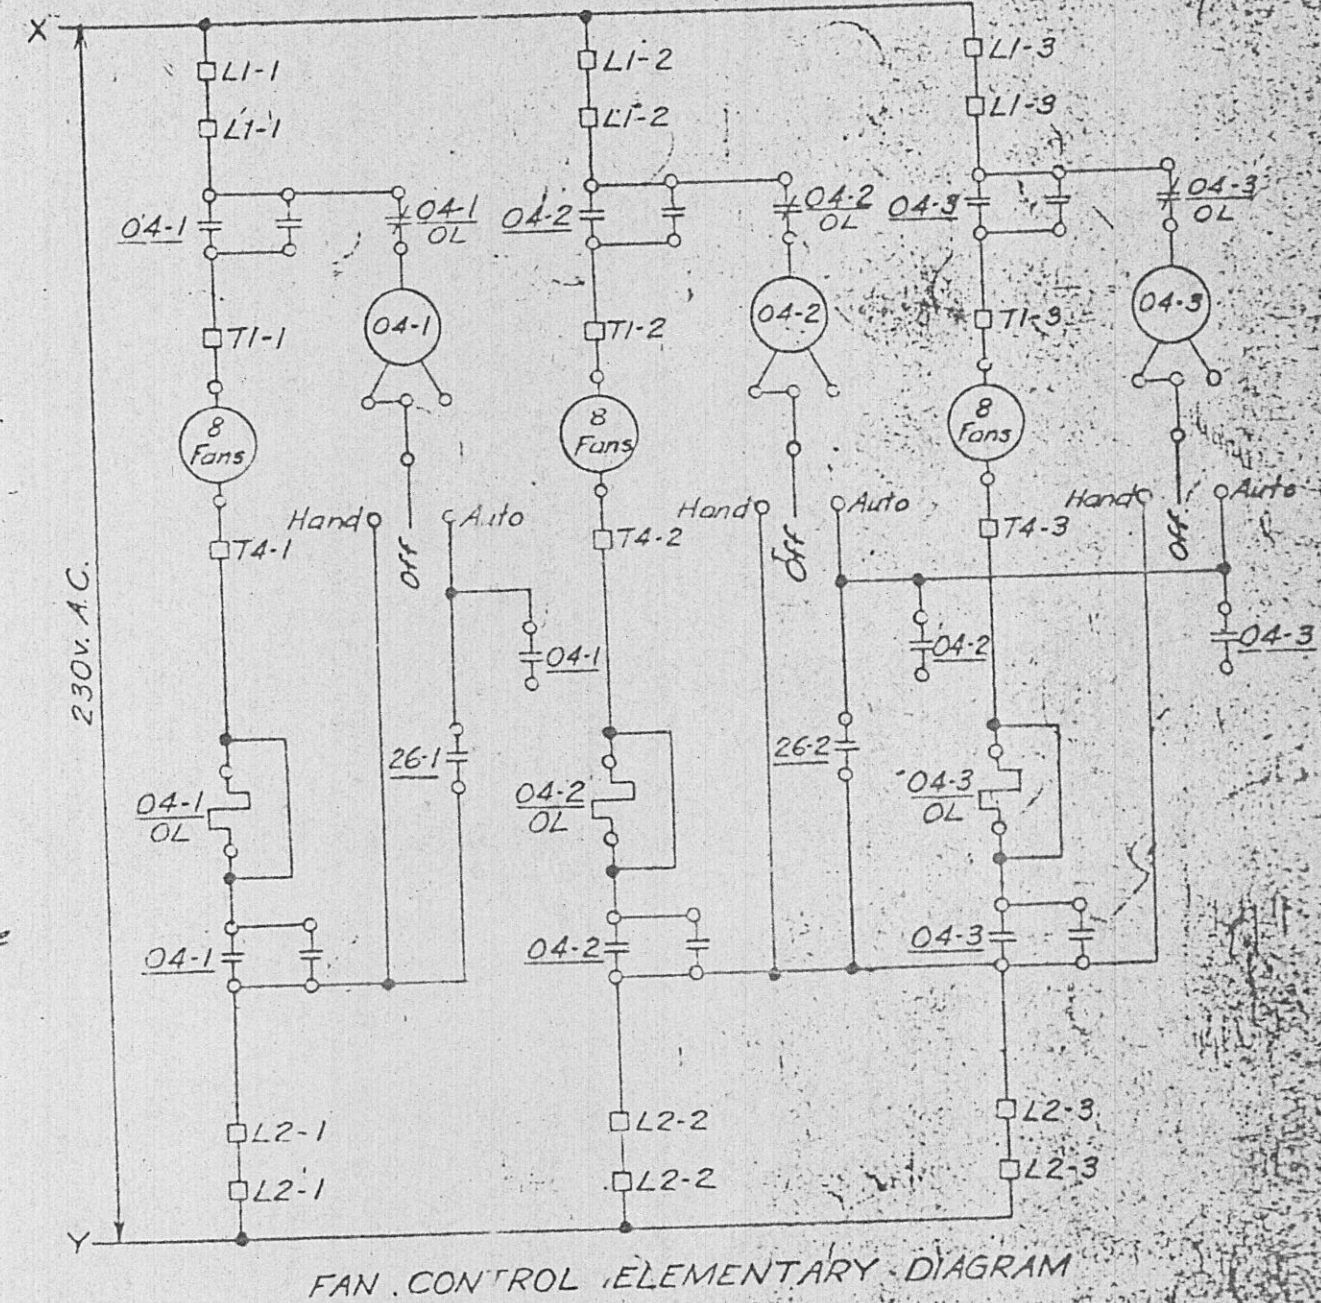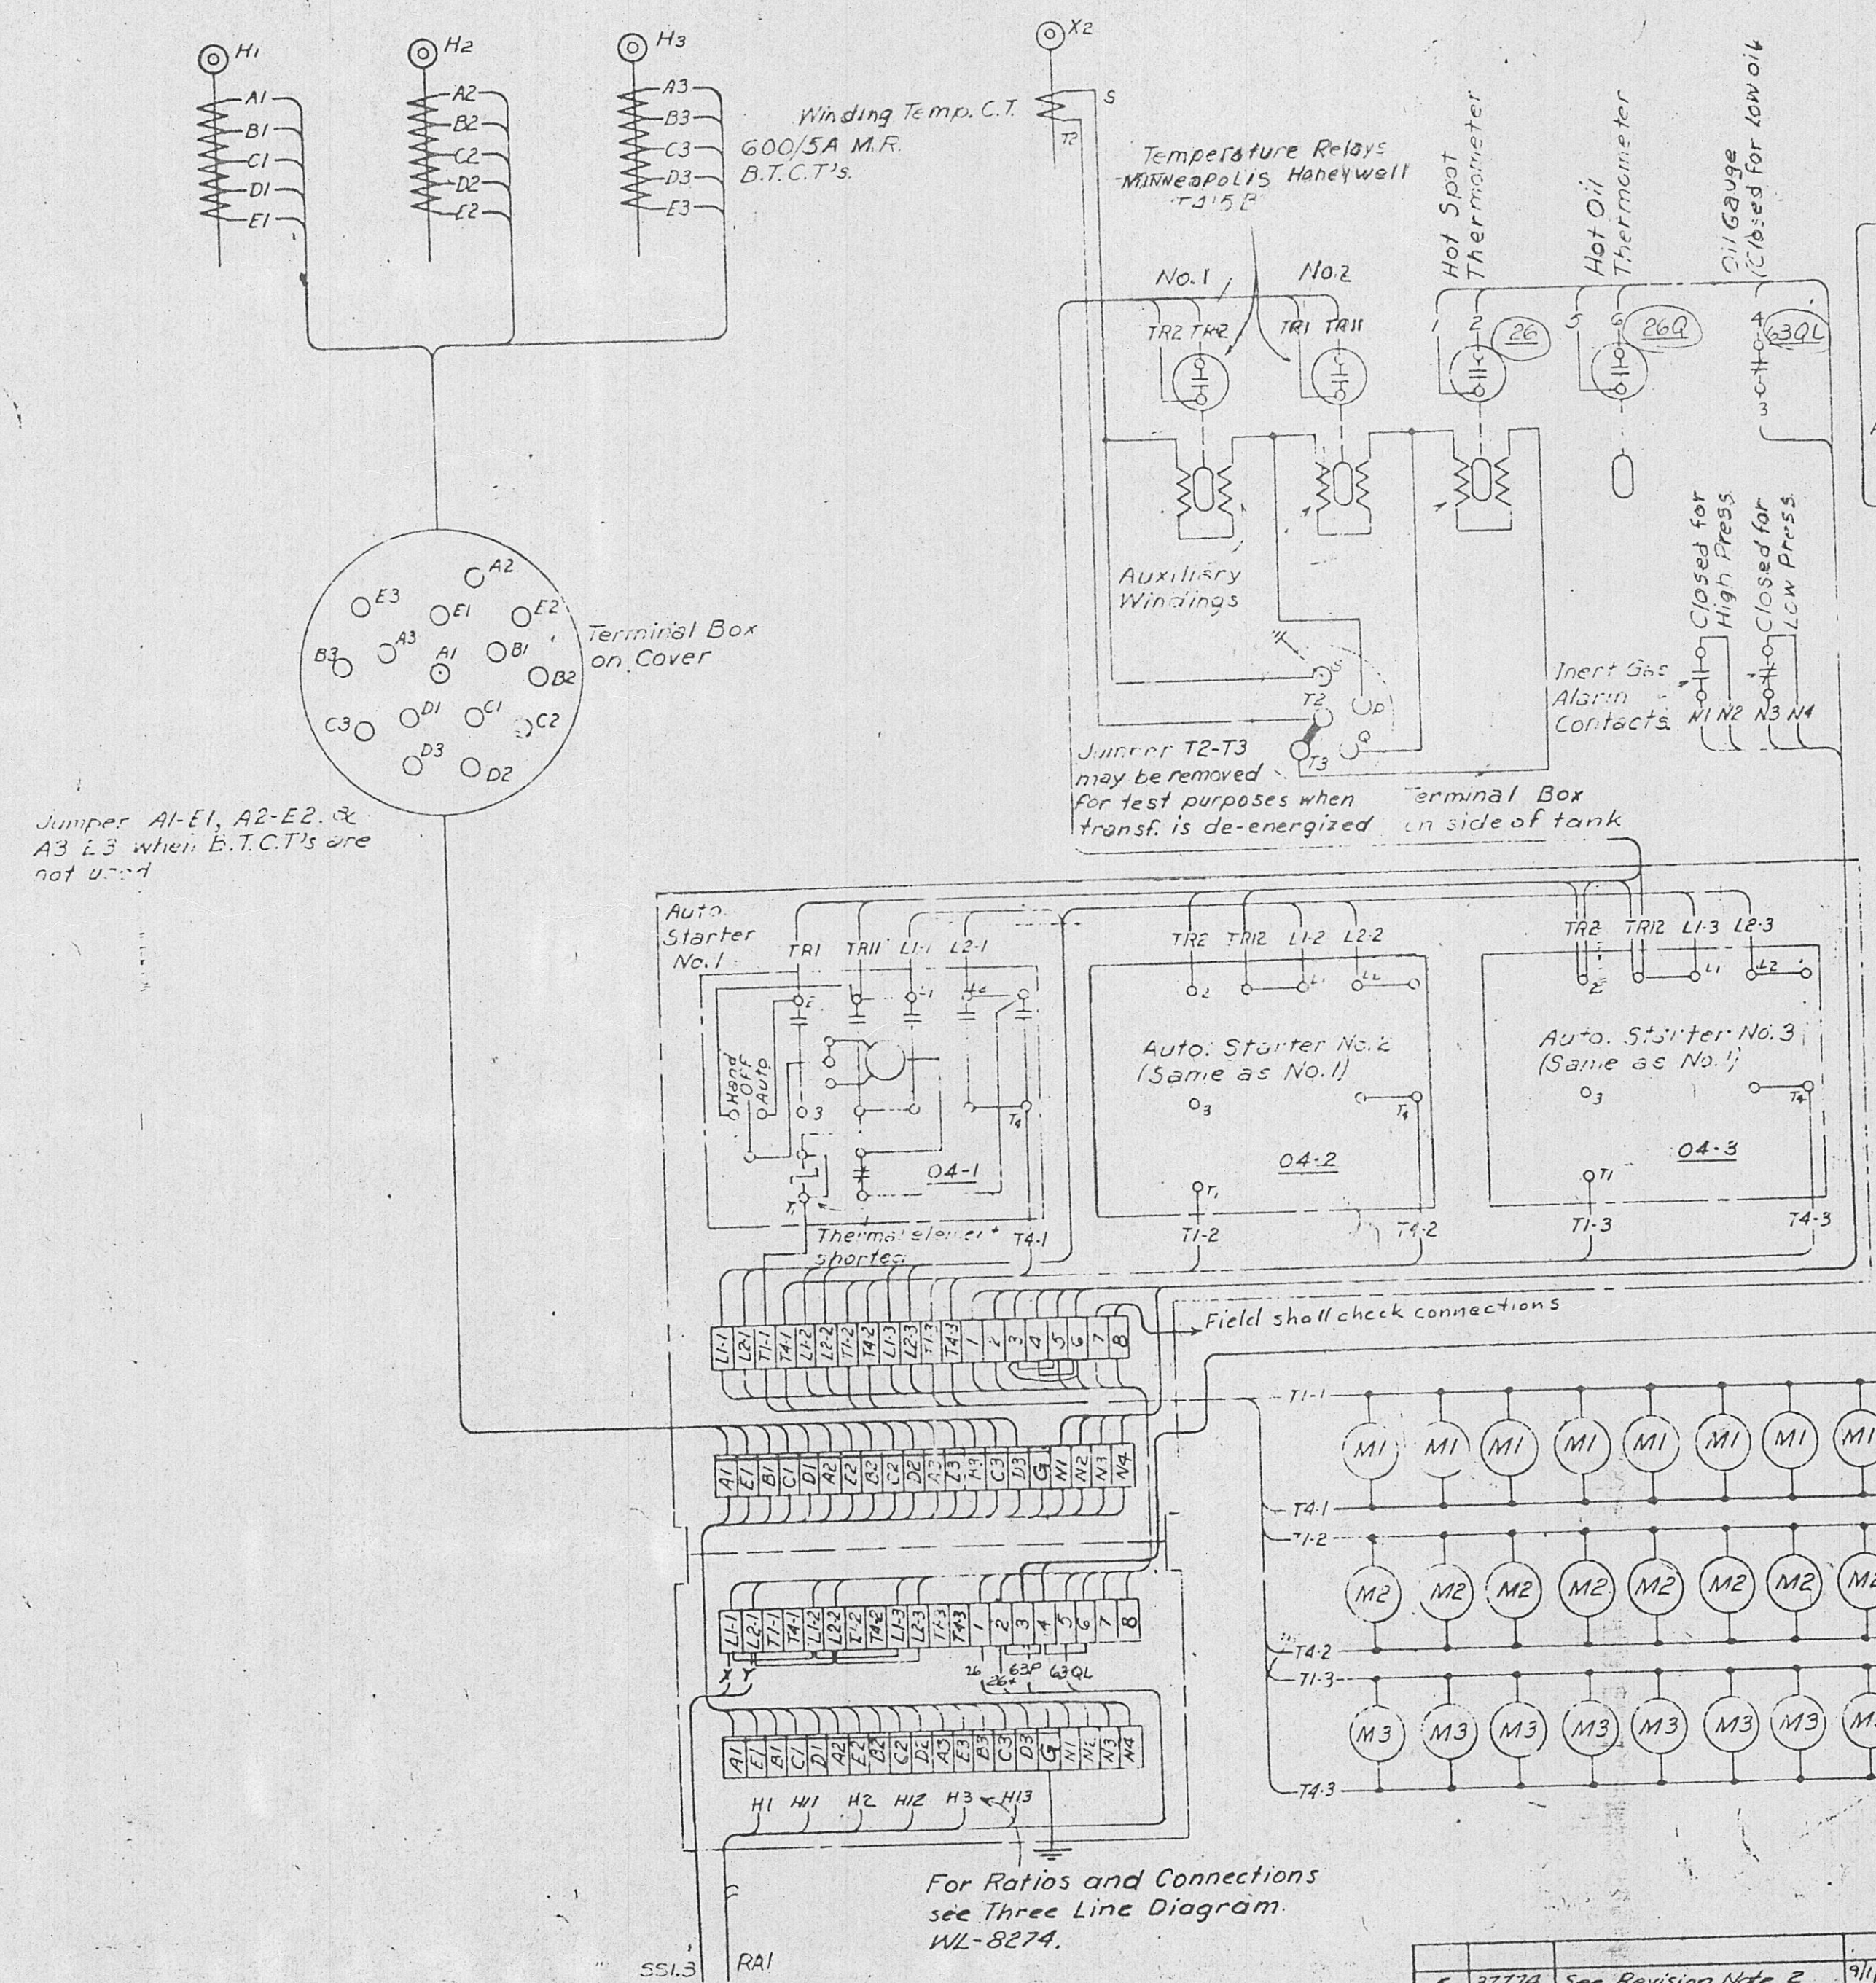

REVISION NOTES:
 1. Moved to Location 2. Added 63P and reconnected points 3 and 4 in split term. box.
 2. Retired from Stock. Moved to location 3. Added jumpers to Term. Block 3-5, 4-6.

REFERENCES:
 Transformer Nameplate Data
 Pol. Ratios, & Taps
 Mfrs. Drawings
 Mfr's Wiring Diagram

LOCATION 1	Calvert Pri.	LOCATION 2	Counce Pri.	LOCATION 3	Church River To NVA
------------	--------------	------------	-------------	------------	---------------------

TENNESSEE VALLEY AUTHORITY
 DEPARTMENT OF POWER ENGINEERING AND CONSTRUCTION
TRANSFORMER ACCESSORIES DIAGRAM
 PENNSYLVANIA 3-φ 15000/20000/25000 KVA
 161000 GRD. Y-13200 VOLTS

REV.	DESCRIPTION	DATE	BY	CHKD.
5	37774 See Revision Note 2	9/1/82	JR	JG
4	Fld. Chg. HMR-105	8/20/77	FWJ	DL
3	44374 See Revision Note 1	5/9/60	DAY	DL
2	45150 Chgd. cables & tagging	8/20/52	Low	DL
1	Field Changes, S.O.S. 3/23/51	4/9/51	HJS	DL

MICROFILMED 5