

CONSTRUCTION PLANS  
FOR  
WASTEWATER SYSTEM IMPROVEMENTS

**HARRIMAN UTILITY BOARD**  
**HARRIMAN, TENNESSEE**


**SOUTH HARRIMAN**  
**PUMP STATIONS REHABILITATION**

CONTRACT S02-03  
NOVEMBER, 2002

WPC 02-1086

APPROVAL EXPIRES  
JAN 15 2004  
TN DEPT. OF ENVIRONMENT & CONSERVATION  
Division of Water Pollution Control

APPROVED FOR CONSTRUCTION  
THE DOCUMENT DESCRIBED IN THIS STAMP HAS BEEN REVIEWED AND REVIEWED BY THE  
TENNESSEE DEPT. OF ENVIRONMENT & CONSERVATION  
DIVISION OF WATER POLLUTION CONTROL  
AND IS HEREBY APPROVED FOR CONSTRUCTION BY THE COMMISSIONER  
JAN 15 2003  
THE APPROVAL SHALL NOT BE CONSTRUED AS CREATING A PRESUMPTION OF  
CORRECT OPERATION OR AS WARRANTING BY THE COMMISSIONER THAT THE  
APPROVED PROJECTS WILL REACH THE DESIGNED GOALS. FOR THE COMMISSIONER  
BY

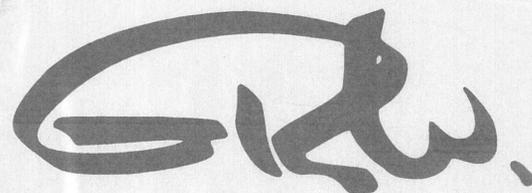

**GRW Elrod Dunson, Inc.**

Engineers, Architects, Planners

404 BNA Drive, Suite 201 NASHVILLE, TN 37217  
PH. (615)366-1600 FAX (615)366-0406

LEXINGTON LOUISVILLE NASHVILLE KNOXVILLE INDIANAPOLIS

Accepted By: \_\_\_\_\_  
Title: MANAGER  
For: HARRIMAN UTILITY BOARD  
Date: \_\_\_\_\_


PROJECT NO. 7601-30

SET NO.



Robert C. Threadgill, 12/2/02

DATE: November 2002

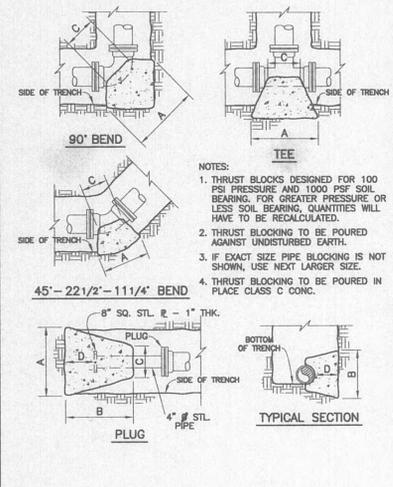

90° BEND		45° BEND	
SIZE	16" 12" 10" 8" 6" 4" 2"	SIZE	16" 12" 10" 8" 6" 4" 2"
A	67 50 42 34 28 18 16	A	48 37 31 25 18 12 12
B	67 50 42 34 28 18 16	B	48 37 31 25 18 12 12
C	30 18 15 12 12 9 9	C	18 16 14 12 12 8 8
D	34 25 21 17 13 9 9	D	24 18 15 12 9 8 8













  

22 1/2° BEND		11 1/4° BEND	
SIZE	16" 12" 10" 8" 6" 4" 2"	SIZE	16" 12" 10" 8" 6" 4" 2"
A	35 26 23 18 13 9 9	A	25 19 16 13 11 9 9
B	35 26 23 18 13 9 9	B	25 19 16 13 11 9 9
C	18 16 14 12 10 8 8	C	18 16 14 12 10 8 8
D	18 13 11 9 6 4 4	D	12 9 8 6 5 4 4

PLUG	
SIZE	16" 12" 10" 8" 6" 4" 2"
A	56 52 43 34 26 26 26
B	56 52 43 34 26 26 26
C	12 12 12 12 12 12 12
D	44 32 22 15 11 11 11

TEE  
DIMENSIONS ARE IN INCHES

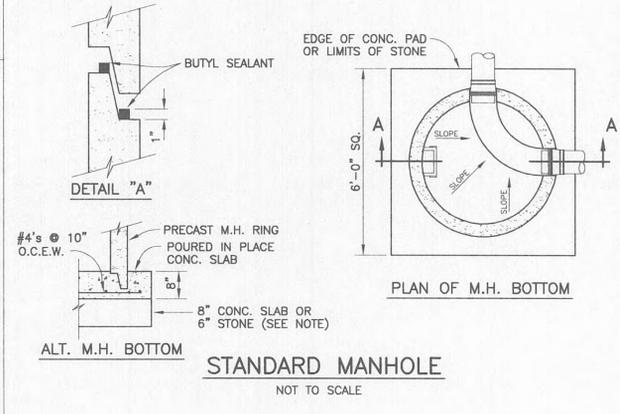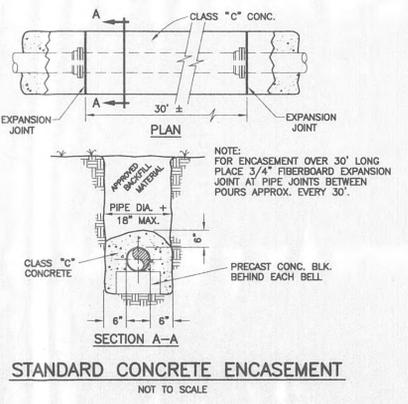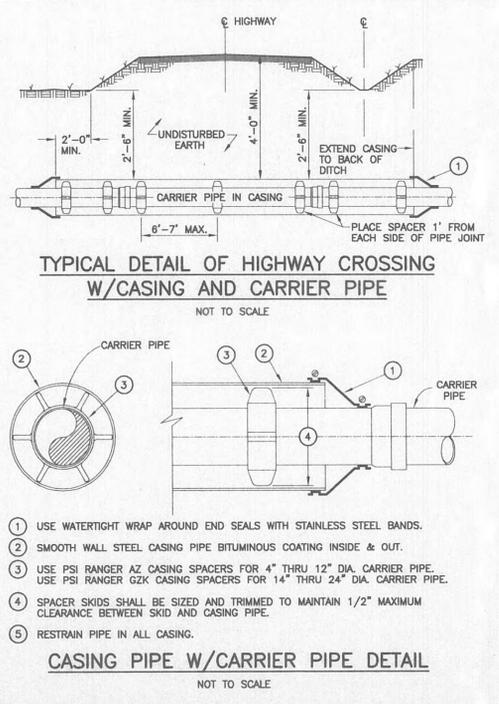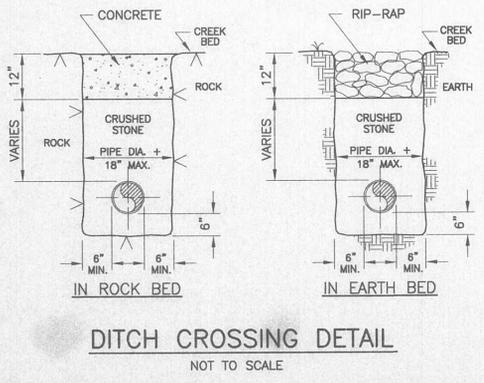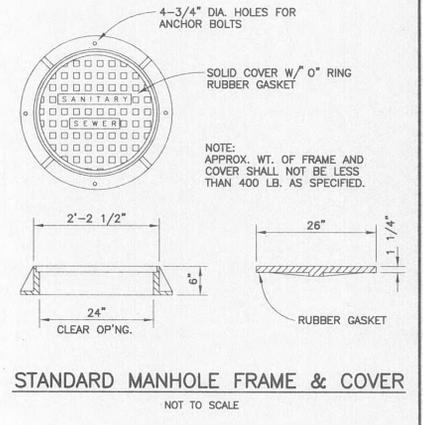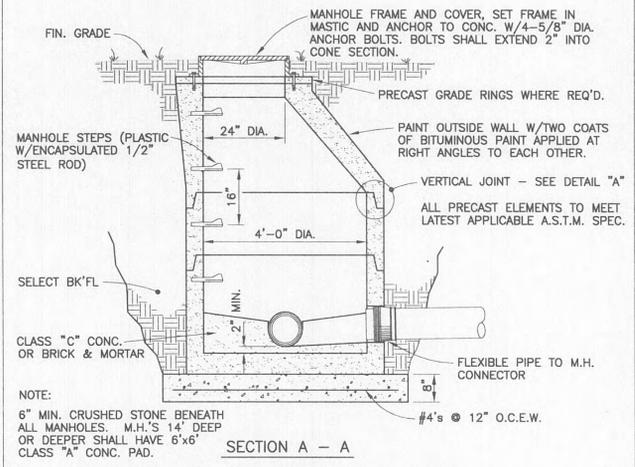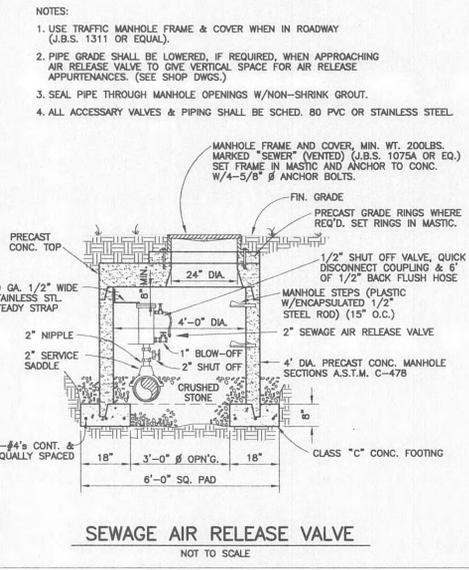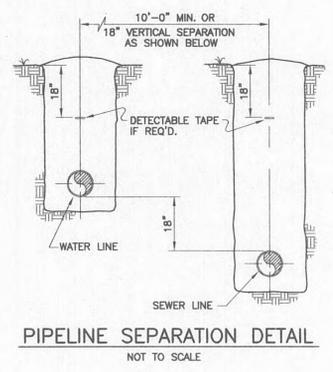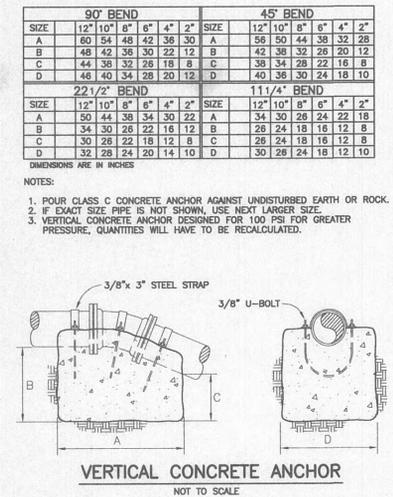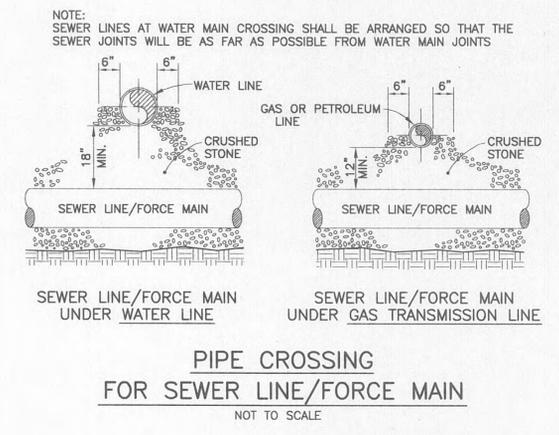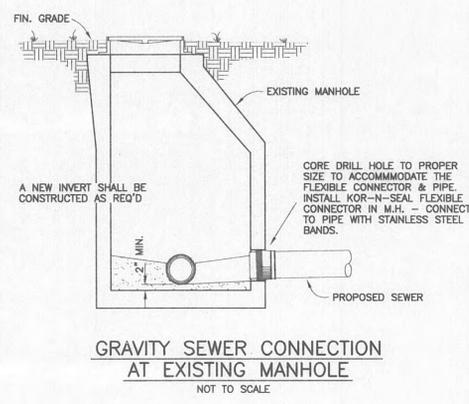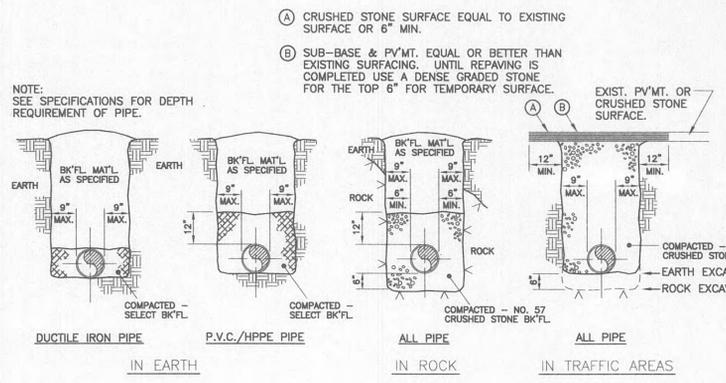

BURIED TELEPHONE CABLES AND UTILITIES  
CALL: TENNESSEE ONE CALL (1-800-351-1111)

ALL RIGHTS RESERVED.  
THIS DOCUMENT IS THE PROPERTY OF GRW EROLD DUNSON, INC. AND SHALL NOT BE REPRODUCED IN WHOLE OR IN PART OR USED FOR CONSTRUCTION OF OTHER THAN THIS SPECIFIC PROJECT WITHOUT WRITTEN PERMISSION OF GRW EROLD DUNSON, INC.

NO.	DESCRIPTION	DATE	BY

GRW PROJECT NO. 7601-30 CONTRACT NO. S02-03  
STANDARD CONSTRUCTION DETAILS  
SOUTH HARRIMAN PUMP STATION REHABILITATION  
HARRIMAN UTILITY BOARD  
HARRIMAN, TENNESSEE

DESIGNED: RGT	DATE: NOVEMBER, 2002
DRAWN: DGR	SCALE: NONE
REVIEWED: RGT	SHEET NO. C-9
APPROVED: RGT	

GRW Erolod Dunson, Inc.  
Engineers, Architects, Planners  
LEXINGTON LOUISVILLE INDIANAPOLIS NASHVILLE KNOXVILLE




FILE NAME: 7601-30-09.dwg

12-2-02

Note: Elevations are Based on Control Monument C.P.-B of Tennessee Highway Department Pine Ridge Road Project. Monument is an Iron Pin (Found) with a Mattern & Craig Eng. Cap. Elevation of 857.24 From Highway Project Plans.

MAP LEGEND

- ⊕ Spike (Found)
- ⊙ Iron Pin (Found)
- Iron Pipe (Found)
- ⊕ Water Meter
- ⊕ Gas Meter
- ⊕ Valve
- ⊕ Power Pole
- ⊕ Light Pole
- Power Line
- ⊕ Drainage Manhole
- ⊕ Sanitary Sewer Manhole
- Proposed Force Main
- 2" Contour
- 10" Contour
- Gas Main
- Water Main
- Ditch/Creek

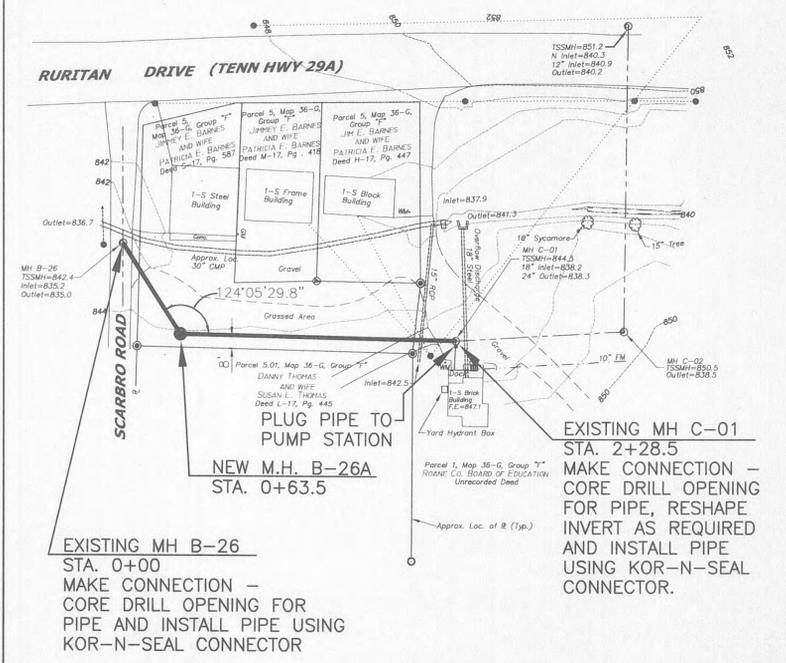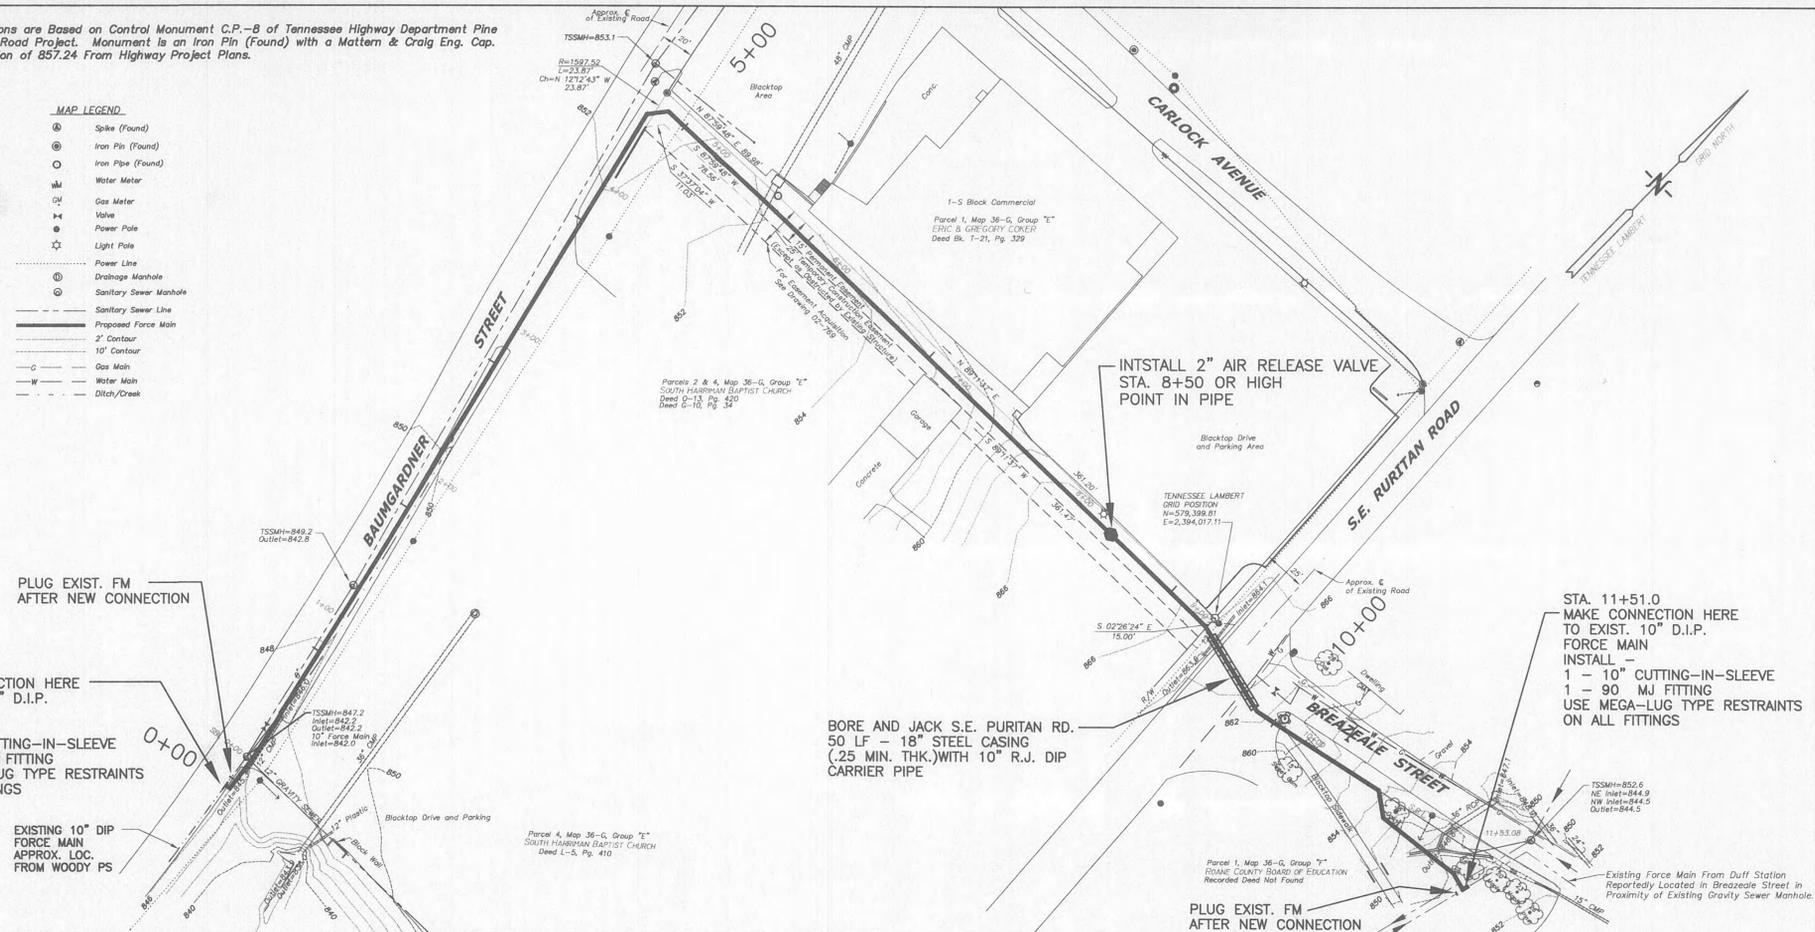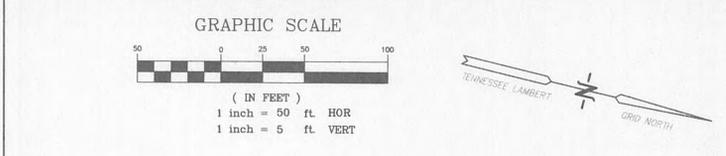

STA. 0+00  
MAKE CONNECTION HERE TO EXIST. 10" D.I.P. FORCE MAIN  
INSTALL -  
1 - 10" CUTTING-IN-SLEEVE  
1 - 90 MJ FITTING  
USE MEGA-LUG TYPE RESTRAINTS ON ALL FITTINGS


EXISTING 10" DIP FORCE MAIN APPROX. LOC. FROM WOODY PS

BORE AND JACK S.E. PURITAN RD. 50 LF - 18" STEEL CASING (.25 MIN. THK.) WITH 10" R.J. DIP CARRIER PIPE

STA. 11+51.0  
MAKE CONNECTION HERE TO EXIST. 10" D.I.P. FORCE MAIN  
INSTALL -  
1 - 10" CUTTING-IN-SLEEVE  
1 - 90 MJ FITTING  
USE MEGA-LUG TYPE RESTRAINTS ON ALL FITTINGS

EXISTING MH B-26  
STA. 0+00  
MAKE CONNECTION - CORE DRILL OPENING FOR PIPE AND INSTALL PIPE USING KOR-N-SEAL CONNECTOR

EXISTING MH C-01  
STA. 2+28.5  
MAKE CONNECTION - CORE DRILL OPENING FOR PIPE, RESHAPE INVERT AS REQUIRED AND INSTALL PIPE USING KOR-N-SEAL CONNECTOR.

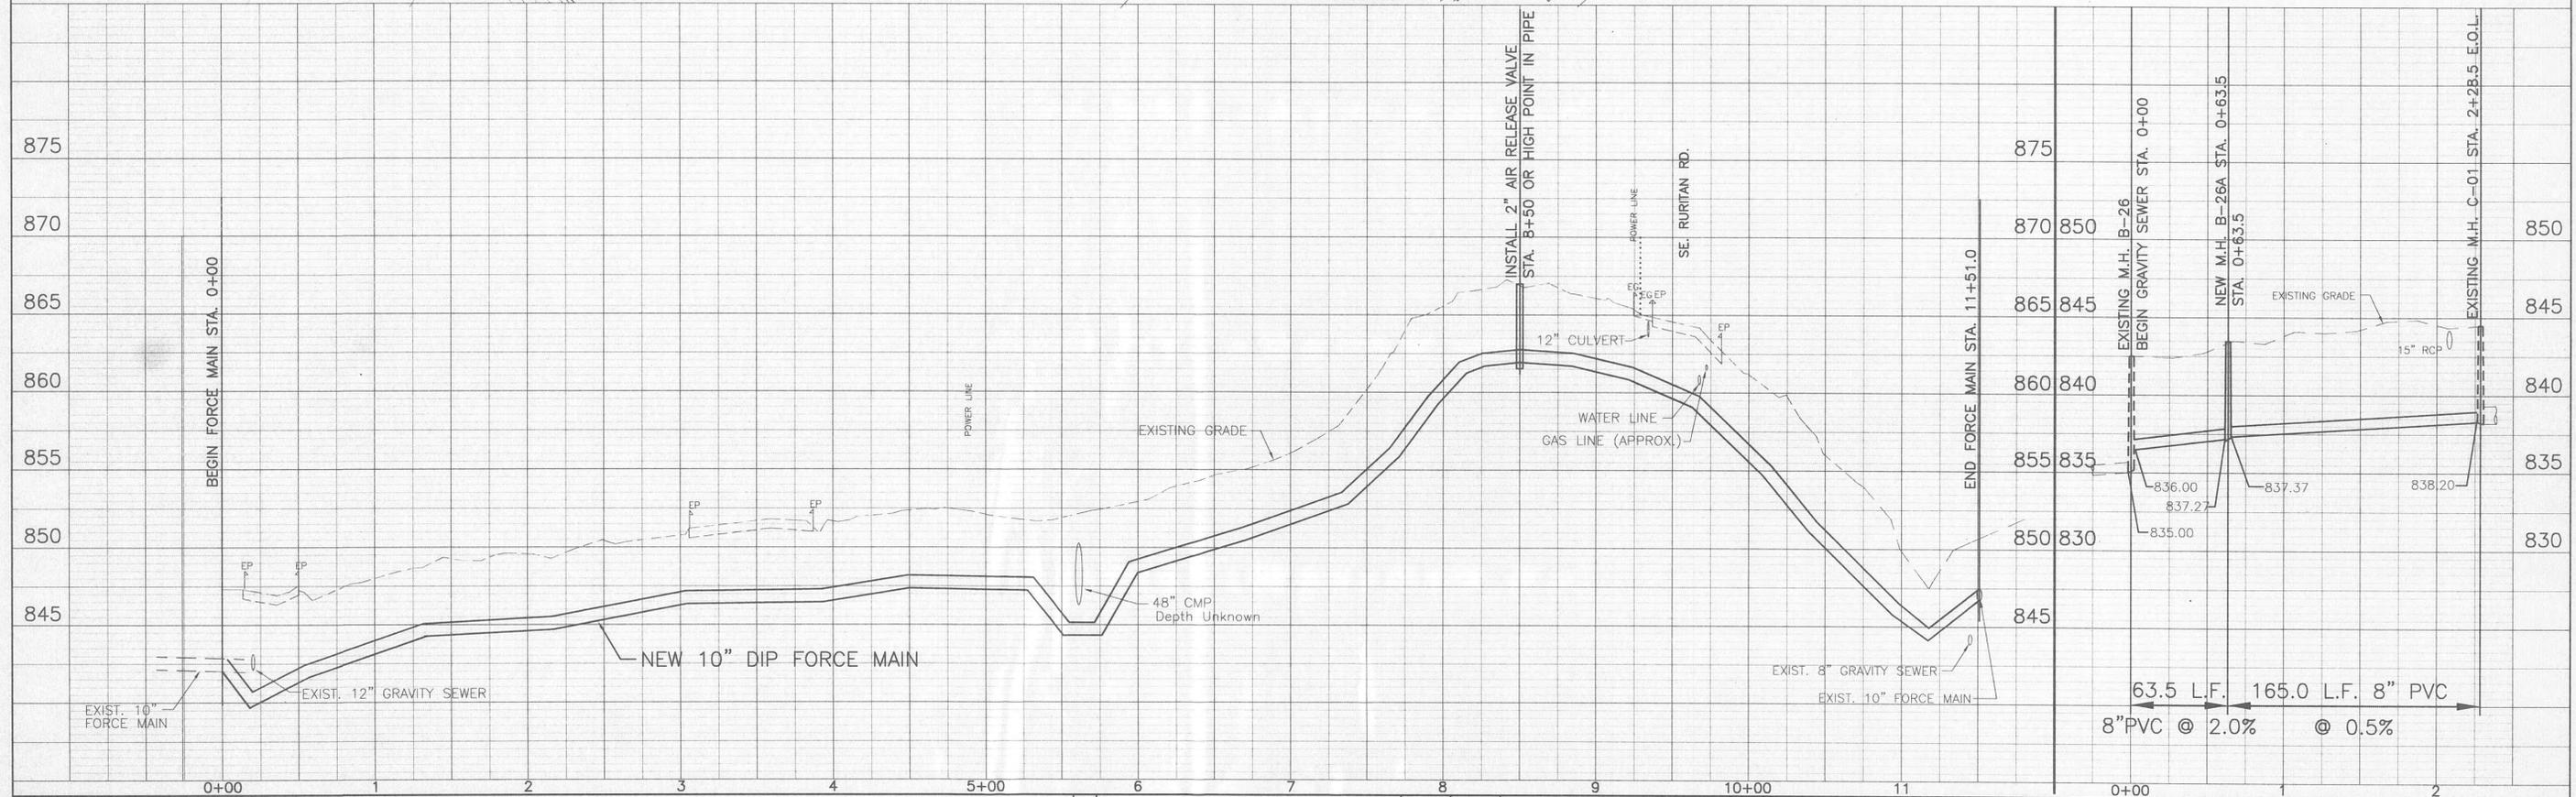


NO.	DESCRIPTION	DATE	BY

FORCE MAIN - STA. 0+00 TO STA. 11+51 E.O.L.			DRAWN: DGR FILE NAME: 7801-30-08.DWG CHECKED: RGT APPROVED: RGT	DATE: NOVEMBER, 2002 SCALE: NOTED SHEET NO. C-8
GRAVITY SEWER - STA. 0+00 TO STA. 2+28.5 E.O.L.			HARRIMAN UTILITY BOARD HARRIMAN, TENNESSEE GRW PROJECT NO. 7801-30 CONTRACT NO. S02-03	

12-2-02

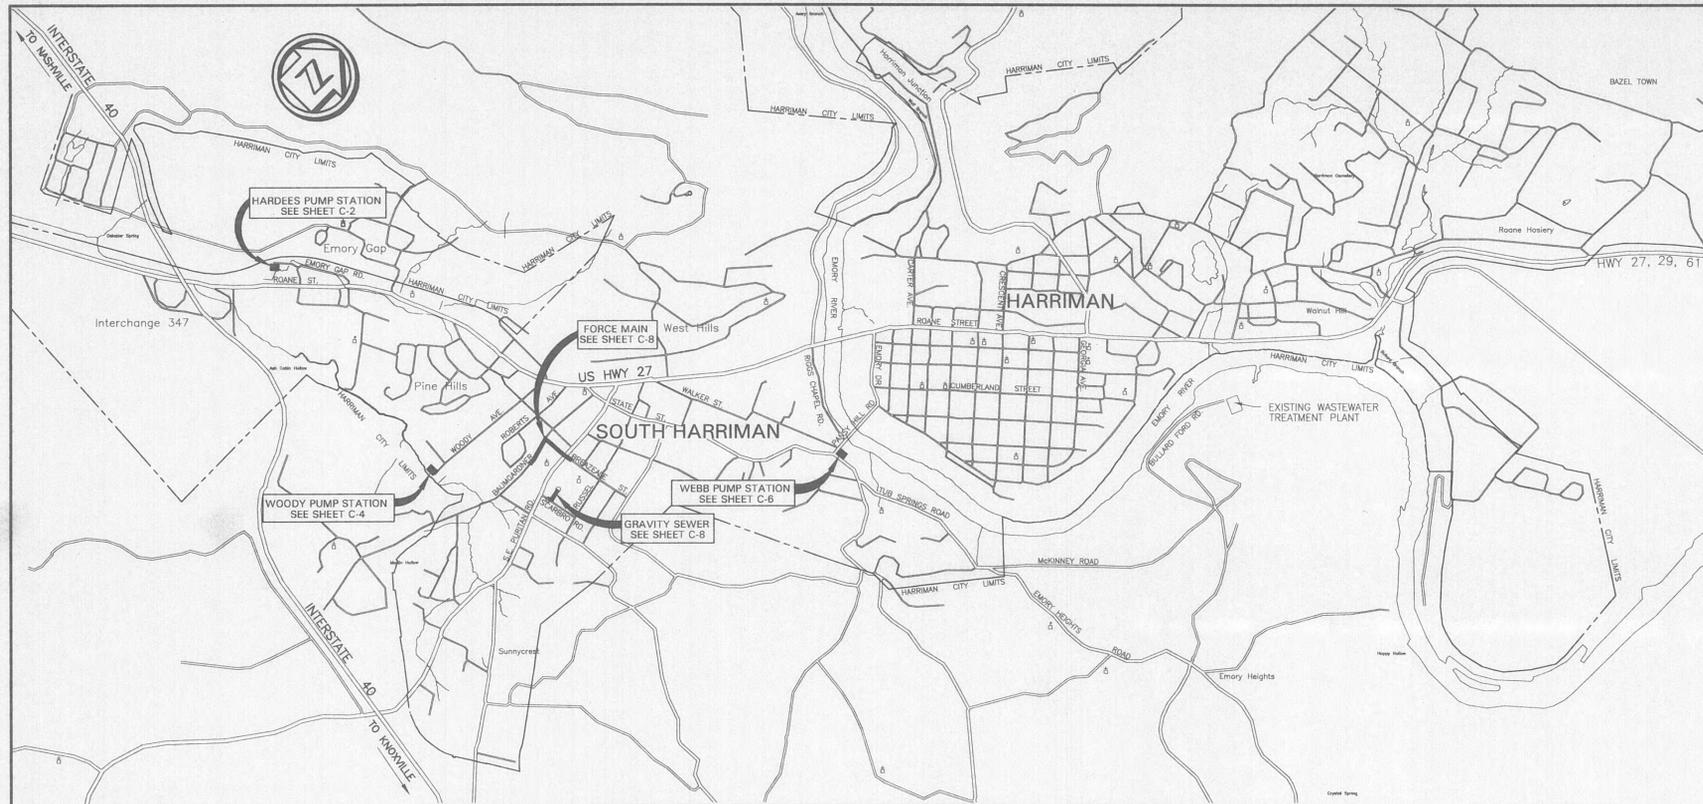

**LOCATION MAP**

SCALE: 1" = 1500'



**VICINITY MAP**

NOT TO SCALE

**INDEX OF SHEETS**

- C-1 LOCATION MAP, VICINITY MAP AND INDEX OF SHEETS
- C-2 EXISTING HARDEES SEWAGE PUMP STATION-PLAN VIEWS
- C-3 EXISTING HARDEES SEWAGE PUMP STATION-SECTIONS
- C-4 EXISTING WOODY ST. SEWAGE PUMP STATION-PLAN VIEWS
- C-5 EXISTING WOODY ST. SEWAGE PUMP STATION-SECTIONS
- C-6 EXISTING WEBB SEWAGE PUMP STATION-PLAN VIEWS
- C-7 EXISTING WEBB SEWAGE PUMP STATION-SECTIONS
- C-8 PLAN AND PROFILE FORCE MAIN STA. 0+00 TO STA. 11+51 E.O.L.  
PLAN AND PROFILE GRAVITY SEWER STA. 0+00 TO STA. 2+28.5 E.O.L.
- C-9 STANDARD CONSTRUCTION DETAILS
  
- A-1 ARCHITECTURAL
- A-2 ARCHITECTURAL
  
- E-1 ELECTRICAL SYMBOLS
- E-2 CONTROL CIRCUIT - HARDEES PUMP STATION
- E-3 HARDEES PUMP STATION ELECTRICAL PLAN & DETAILS
- E-4 CONTROL CIRCUIT - WEBB PUMP STATION
- E-5 WEBB PUMP STATION ELECTRICAL PLAN & DETAILS
- E-6 CONTROL CIRCUIT - WOODY ST. PUMP STATION
- E-7 WOODY ST. PUMP STATION ELECTRICAL PLAN & DETAILS
  
- M-1 MECHANICAL
- M-2 MECHANICAL
- M-3 MECHANICAL
- M-4 MECHANICAL


FILE NAME: 7601-30

GRW PROJECT NO. 7601-30 CONTRACT NO. S02-03

LOCATION PLAN, VICINITY MAP  
INDEX OF DRAWINGS  
SOUTH HARRIMAN PUMP STATIONS REHABILITATION  
HARRIMAN UTILITY BOARD - HARRIMAN, TENNESSEE


ALL RIGHTS RESERVED.  
THIS DOCUMENT IS THE PROPERTY OF GRW ENGINEERS, INC. AND SHALL NOT BE REPRODUCED IN WHOLE OR IN PART OR USED FOR CONSTRUCTION OF OTHER THAN THIS SPECIFIC PROJECT WITHOUT WRITTEN PERMISSION OF GRW ENGINEERS, INC.

NO.	DESCRIPTION	DATE	BY

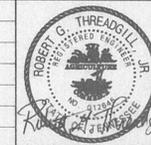


DESIGNER: RGT	DATE: NOVEMBER, 2002
DRAWN: DGR	SCALE: AS NOTED
REVIEWED: RGO	SHEET NO. C-1
APPROVED: RGT	

12-2-02

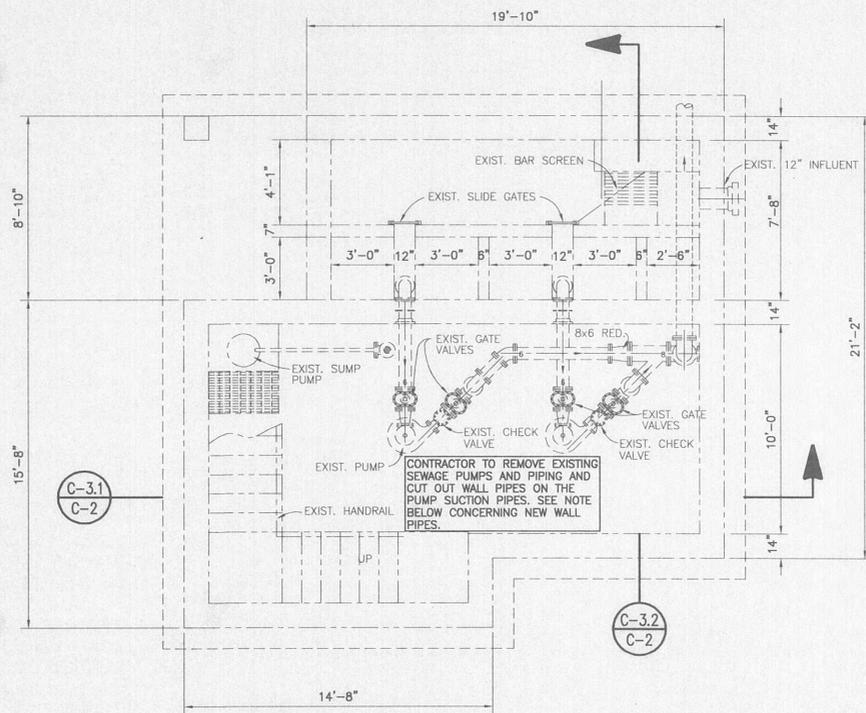


**EXISTING FLOOR PLAN - PUMP LEVEL**  
SCALE: 1/4" = 1'-0"

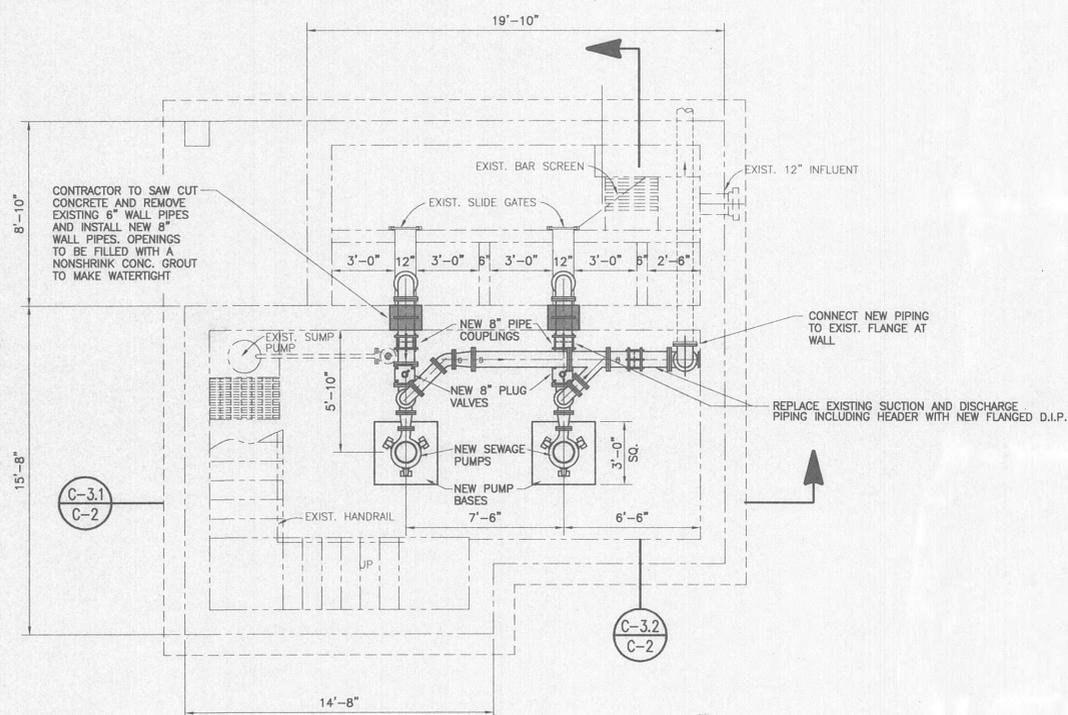


**MODIFIED FLOOR PLAN - PUMP LEVEL**  
SCALE: 1/4" = 1'-0"

**CONTRACTOR NOTES:**

1. CONTRACTOR SHALL BE RESPONSIBLE FOR BYPASS PUMPING WHILE REHABILITATING PUMP STATION. THIS INCLUDES ANY REQUIRED CONNECTIONS TO INFLUENT AND DISCHARGE LINES. HUB WILL PROVIDE THE REQUIRED ELECTRICAL SERVICE FOR BYPASS PUMPING.
2. THE OWNER SHALL HAVE FIRST SALVAGE RIGHTS TO ALL EXISTING VALVES, PIPING AND EQUIPMENT. IF THE OWNER REJECTS SALVAGED MATERIALS, THE CONTRACTOR SHALL PROVIDE FINAL DISPOSAL OF ALL ITEMS.
3. CONTRACTOR TO CLEAN AND PAINT PIPING AND WALLS. WALLS INCLUDE ENTRANCE LEVEL. ELECTRICAL AREA AND PUMP LEVEL: PUMP AND PIPING AREA.

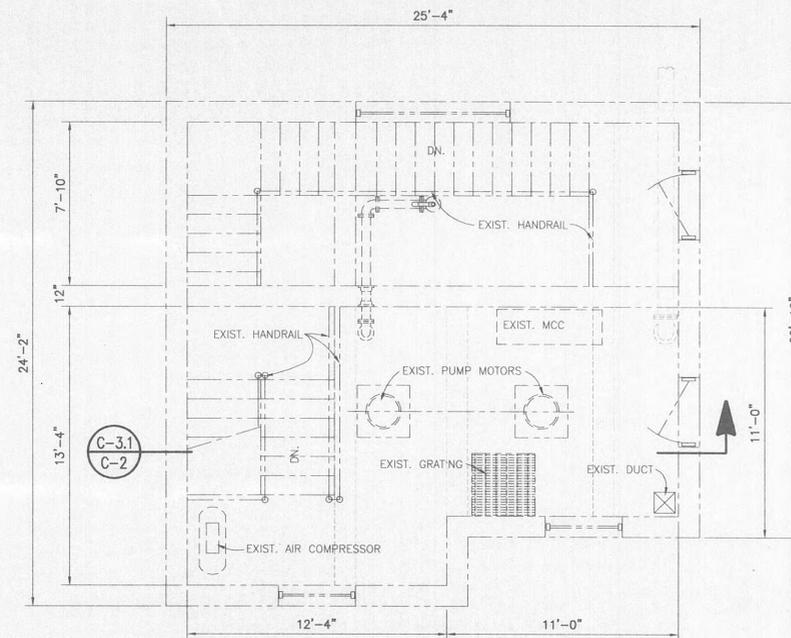

**EXISTING FLOOR PLAN - ENTRANCE LEVEL**  
SCALE: 1/4" = 1'-0"

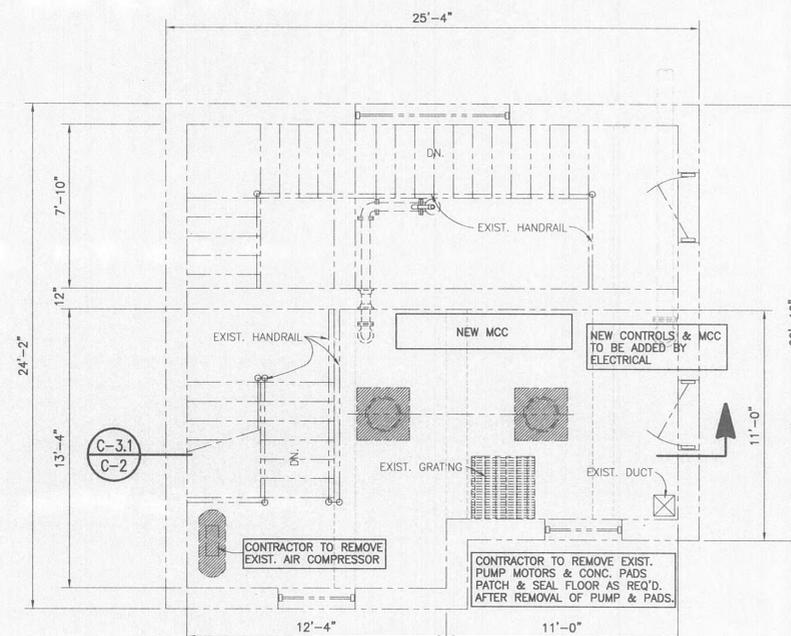


**MODIFIED FLOOR PLAN - ENTRANCE LEVEL**  
SCALE: 1/4" = 1'-0"

FILE NAME: 7601-30

GRW PROJECT NO. 7601-30 CONTRACT NO. S02-03  
**EXISTING HARDEES SEWAGE PUMP STATION**  
 PLAN VIEWS  
 HARRIMAN UTILITY BOARD  
 HARRIMAN, TENNESSEE


THIS DOCUMENT IS THE PROPERTY OF GRW ELROD DUNSON, INC. AND SHALL NOT BE REPRODUCED IN WHOLE OR IN PART OR USED FOR CONSTRUCTION OF OTHER THAN THIS SPECIFIC PROJECT WITHOUT WRITTEN PERMISSION OF GRW ELROD DUNSON, INC.

NO.	DESCRIPTION	DATE	BY

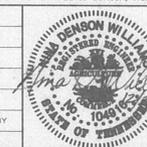


**GRW Elrod Dunson, Inc.**  
 Engineers, Architects, Planners  
 LEXINGTON LOUISVILLE INDIANAPOLIS  
 NASHVILLE KNOXVILLE


DESIGNED: RGT/NDW	DATE: NOVEMBER, 2002
DRAWN: DGR	SCALE: AS NOTED
REVIEWED: NDW	SHEET NO. C-2
APPROVED: RGT	

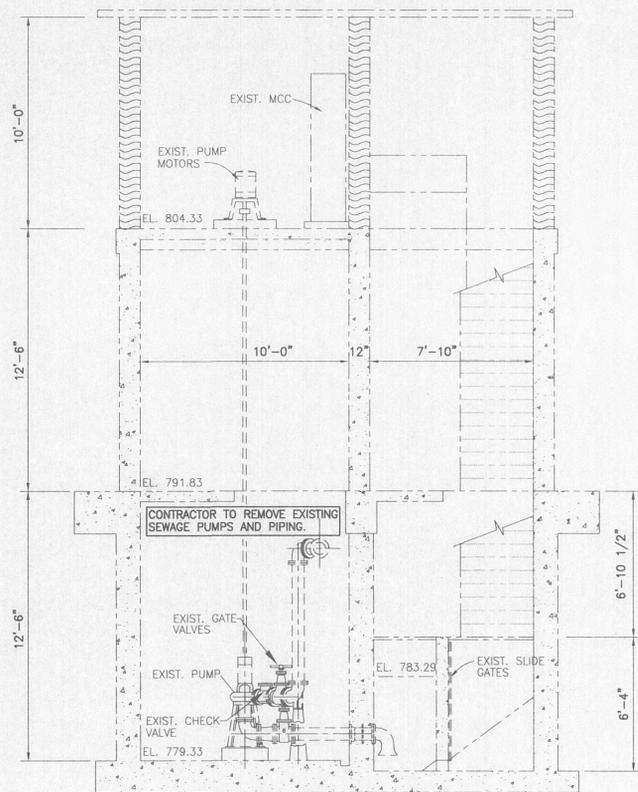


EXISTING CONDITIONS—SECTION C-3.2  
SCALE: 1/4" = 1'-0"  
C-2

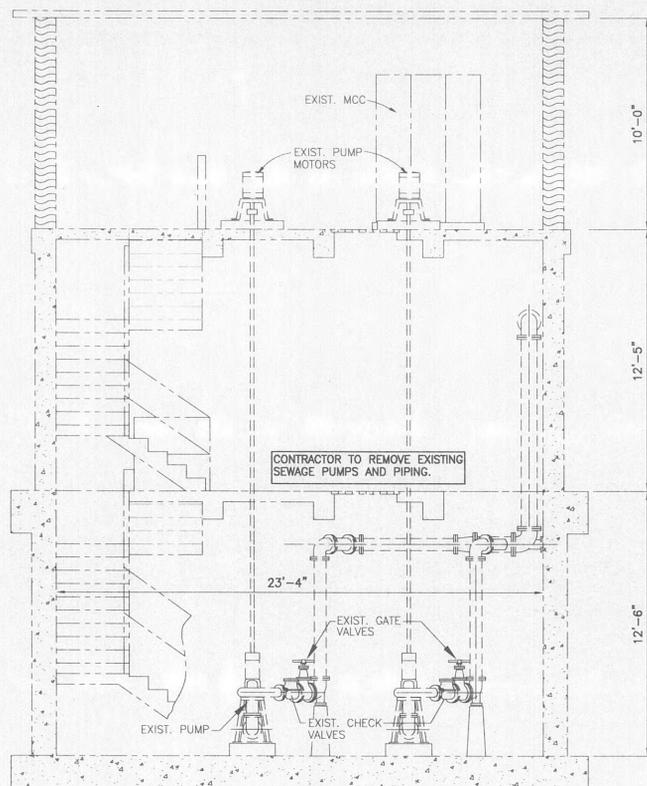

EXISTING CONDITIONS—SECTION C-3.1  
SCALE: 1/4" = 1'-0"  
C-2

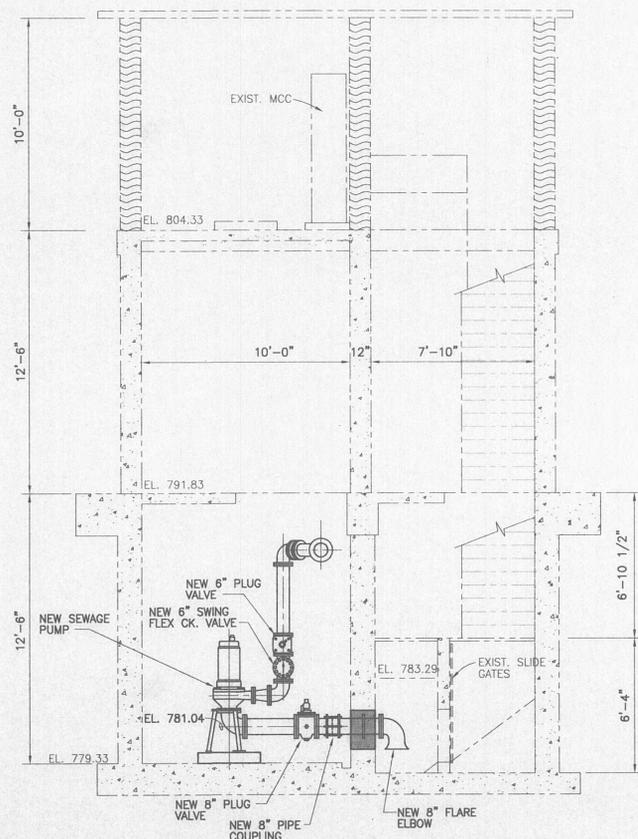

MODIFIED CONDITIONS—SECTION C-3.2  
SCALE: 1/4" = 1'-0"  
C-2

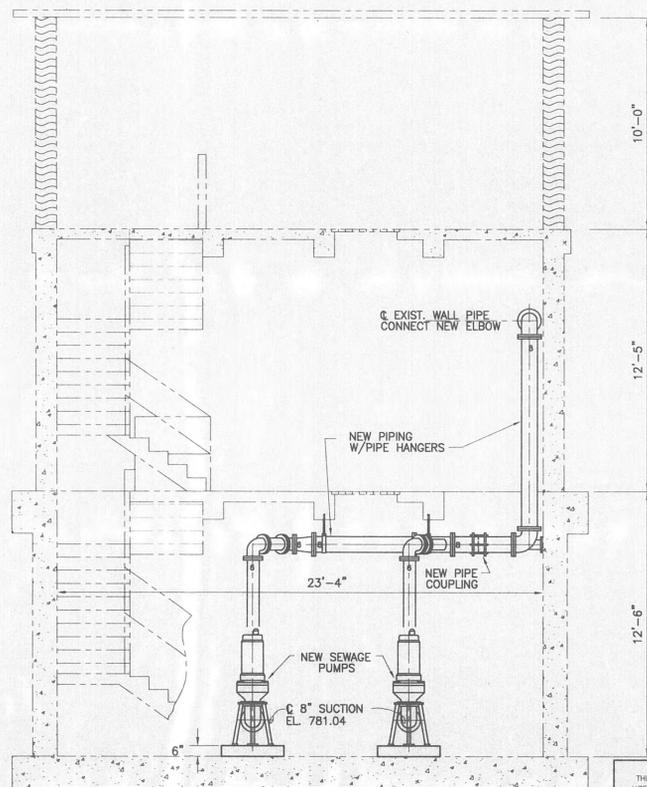

MODIFIED CONDITIONS—SECTION C-3.1  
SCALE: 1/4" = 1'-0"  
C-2

ALL RIGHTS RESERVED.  
THIS DOCUMENT IS THE PROPERTY OF GRW ELROD DUNSON, INC. AND SHALL NOT BE REPRODUCED IN WHOLE OR IN PART OR USED FOR CONSTRUCTION OF OTHER THAN THIS SPECIFIC PROJECT WITHOUT WRITTEN PERMISSION OF GRW ELROD DUNSON, INC.


NO.	DESCRIPTION	DATE	BY



GRW PROJECT NO. 7601-30 CONTRACT NO. S02-03  
EXISTING HARDEES SEWAGE PUMP STATION SECTIONS  
HARRIMAN UTILITY BOARD  
HARRIMAN, TENNESSEE

DESIGNED: RGT/NDW	DATE: NOVEMBER, 2002
DRAWN: DGR	SCALE: AS NOTED
REVIEWED: NDW	SHEET NO. C-3
APPROVED: RGT	




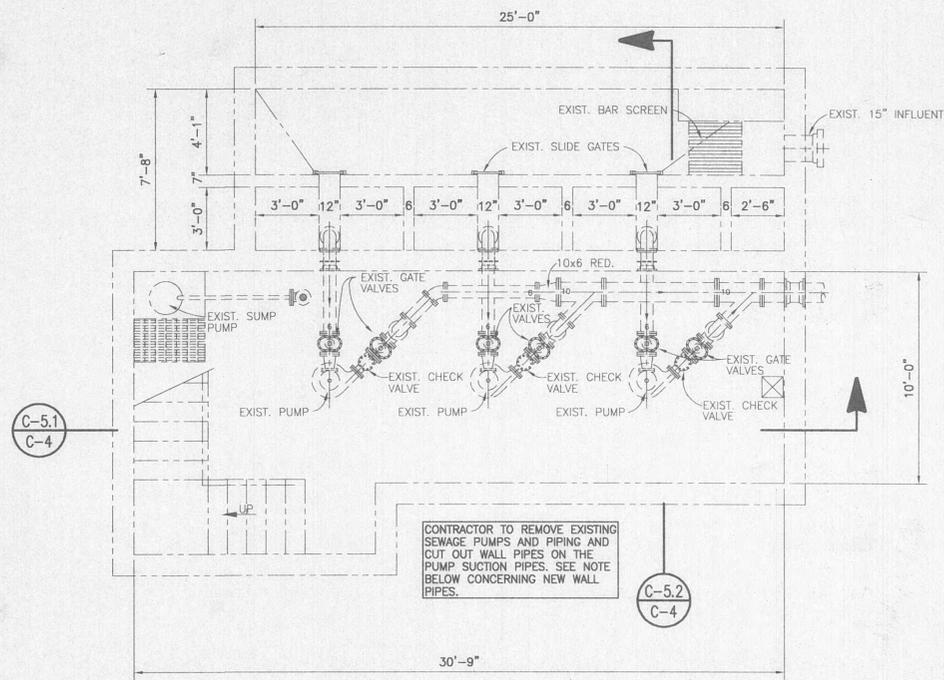


**EXISTING FLOOR PLAN - PUMP LEVEL**  
SCALE: 1/4" = 1'-0"

**CONTRACTOR NOTES:**


1. CONTRACTOR SHALL BE RESPONSIBLE FOR BYPASS PUMPING WHILE REHABILITATING PUMP STATION. THIS INCLUDES ANY REQUIRED CONNECTIONS TO INFLUENT AND DISCHARGE LINES. HUB WILL PROVIDE THE REQUIRED ELECTRICAL SERVICE FOR BYPASS PUMPING.
2. THE OWNER SHALL HAVE FIRST SALVAGE RIGHTS TO ALL EXISTING VALVES, PIPING AND EQUIPMENT. IF THE OWNER REJECTS SALVAGED MATERIALS, THE CONTRACTOR SHALL PROVIDE FINAL DISPOSAL OF ALL ITEMS.
3. CONTRACTOR TO CLEAN AND PAINT PIPING AND WALLS. WALLS INCLUDE ENTRANCE LEVEL: ELECTRICAL AREA AND PUMP LEVEL: PUMP AND PIPING AREA.

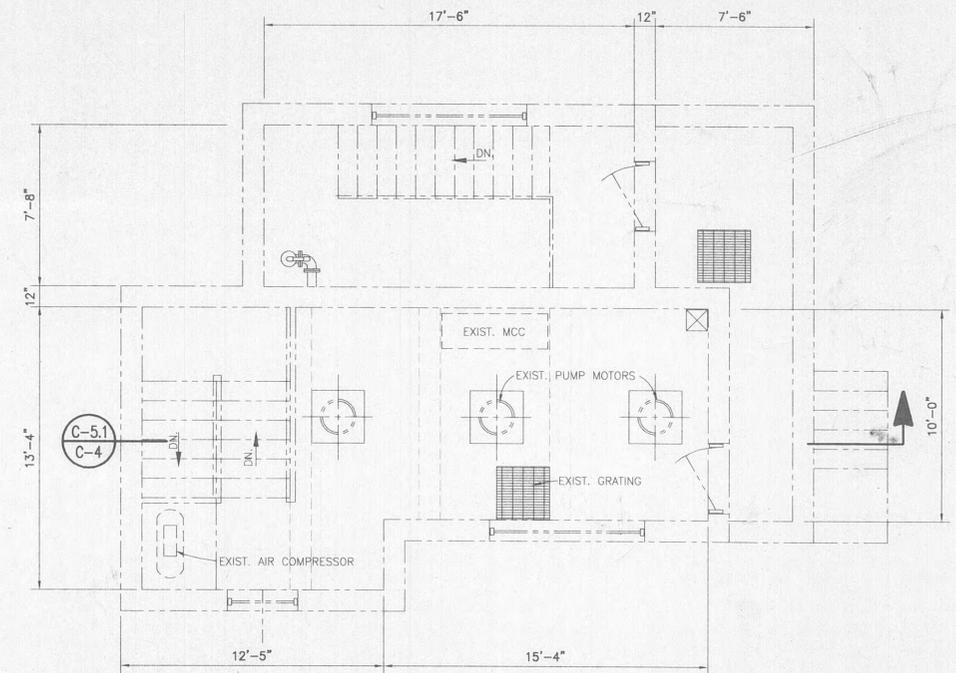

**EXISTING FLOOR PLAN - ENTRANCE LEVEL**  
SCALE: 1/4" = 1'-0"

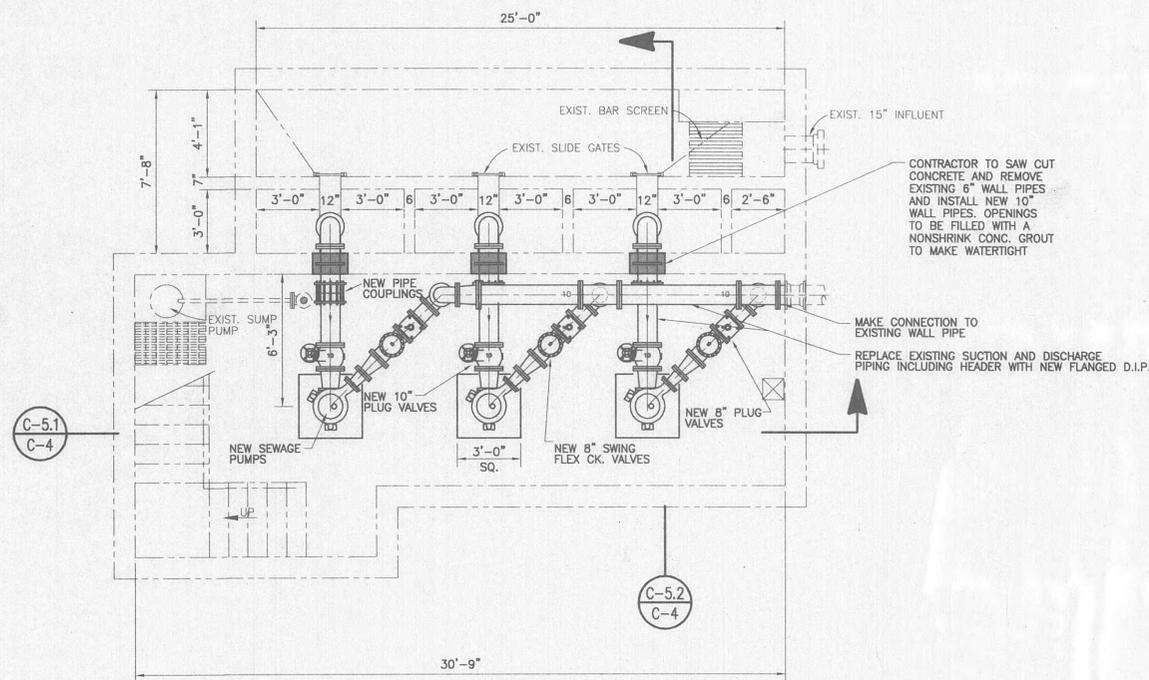

**MODIFIED FLOOR PLAN - PUMP LEVEL**  
SCALE: 1/4" = 1'-0"

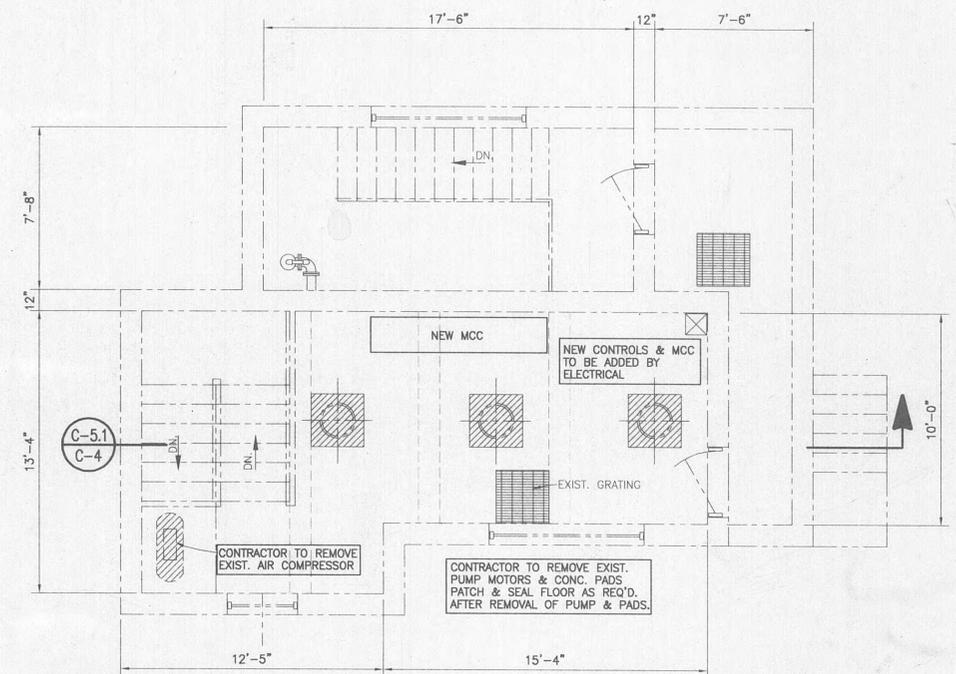


**MODIFIED FLOOR PLAN - ENTRANCE LEVEL**  
SCALE: 1/4" = 1'-0"


GRW PROJECT NO. 7601-30 CONTRACT NO. S02-03  
**EXISTING WOODY ST. SEWAGE PUMP STATION**  
**PLAN VIEWS**  
**HARRIMAN UTILITY BOARD**  
**HARRIMAN, TENNESSEE**

ALL RIGHTS RESERVED.  
 THIS DOCUMENT IS THE PROPERTY OF GRW ELROD DUNSON, INC. AND SHALL NOT BE REPRODUCED IN WHOLE OR IN PART OR USED FOR CONSTRUCTION OF OTHER THAN THIS SPECIFIC PROJECT WITHOUT WRITTEN PERMISSION OF GRW ELROD DUNSON, INC.


NO.	DESCRIPTION	DATE	BY

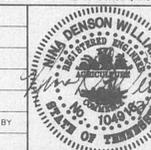


DESIGNED: RGT/NDW	DATE: NOVEMBER, 2002
DRAWN: DGR	SCALE: AS NOTED
REVIEWED: NDW	SHEET NO. C-4
APPROVED: RGT	

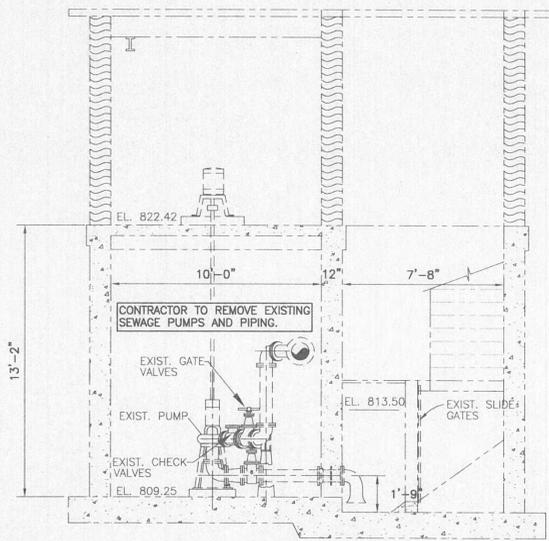


EXISTING CONDITIONS—SECTION C-5.2  
SCALE: 1/4" = 1'-0"  
C-4

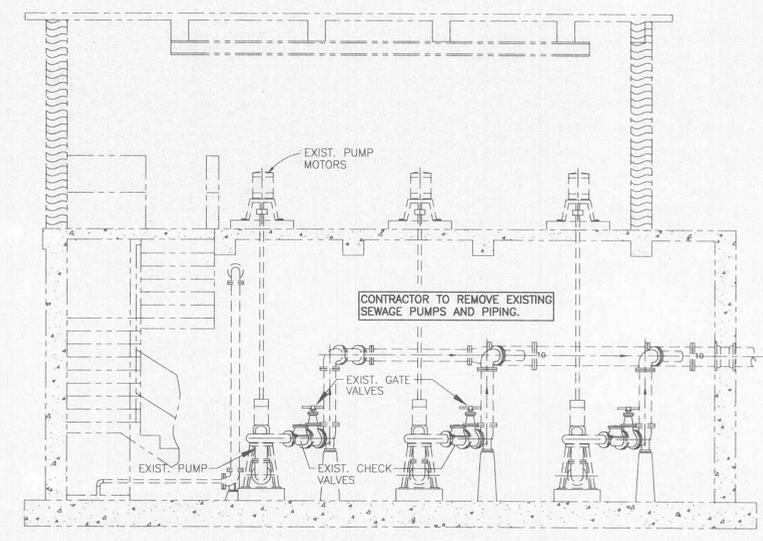

EXISTING CONDITIONS—SECTION C-5.1  
SCALE: 1/4" = 1'-0"  
C-4

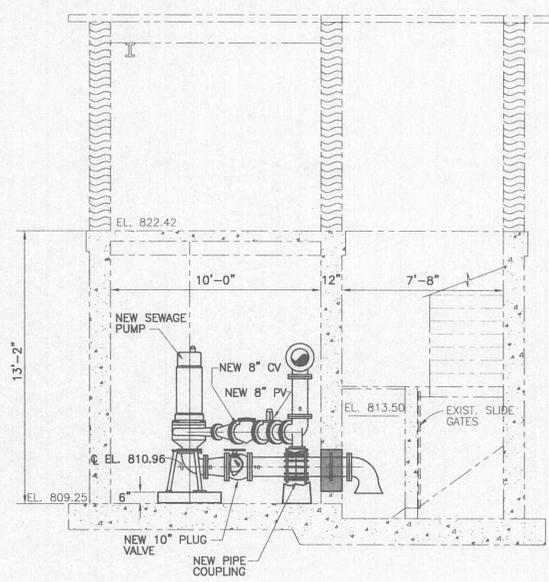

MODIFIED CONDITIONS—SECTION C-5.2  
SCALE: 1/4" = 1'-0"  
C-4

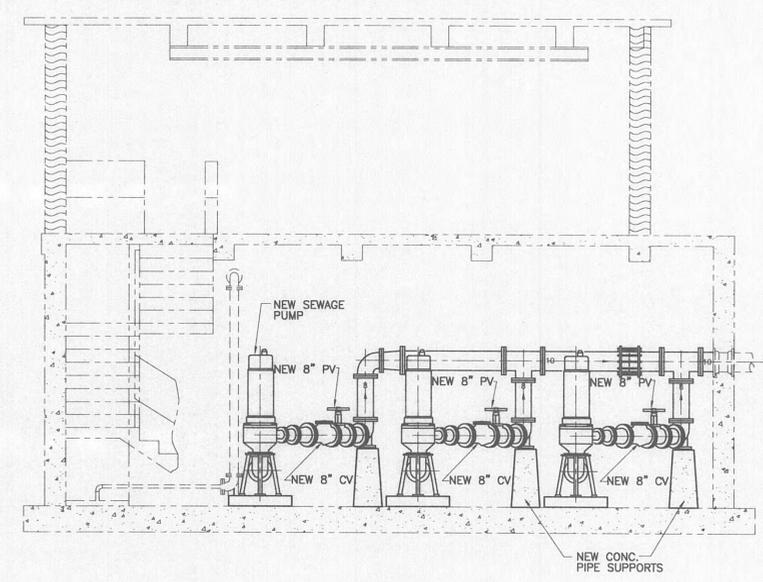


MODIFIED CONDITIONS—SECTION C-5.1  
SCALE: 1/4" = 1'-0"  
C-4

GRW PROJECT NO. 7601-30 CONTRACT NO. S02-03

EXISTING WOODY ST. SEWAGE PUMP STATION SECTIONS  
HARRIMAN UTILITY BOARD  
HARRIMAN, TENNESSEE

THIS DOCUMENT IS THE PROPERTY OF GRW ELROD DUNSON, INC. AND SHALL NOT BE REPRODUCED IN WHOLE OR IN PART OR USED FOR CONSTRUCTION OF OTHER THAN THIS SPECIFIC PROJECT WITHOUT WRITTEN PERMISSION OF GRW ELROD DUNSON, INC.


NO.	DESCRIPTION	DATE	BY

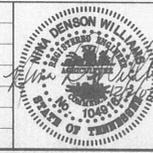

**GRW**  
GRW Elrod Dunson, Inc.  
Engineers, Architects, Planners  
LEXINGTON LOUISVILLE INDIANAPOLIS  
NASHVILLE KNOXVILLE


DESIGNED: RGT/NDW	DATE: NOVEMBER, 2002
DRAWN: DGR	SCALE: AS NOTED
REVIEWED: NDW	SHEET NO. C-5
APPROVED: RGT	

FILE NAME: 7601-30-05.DWG

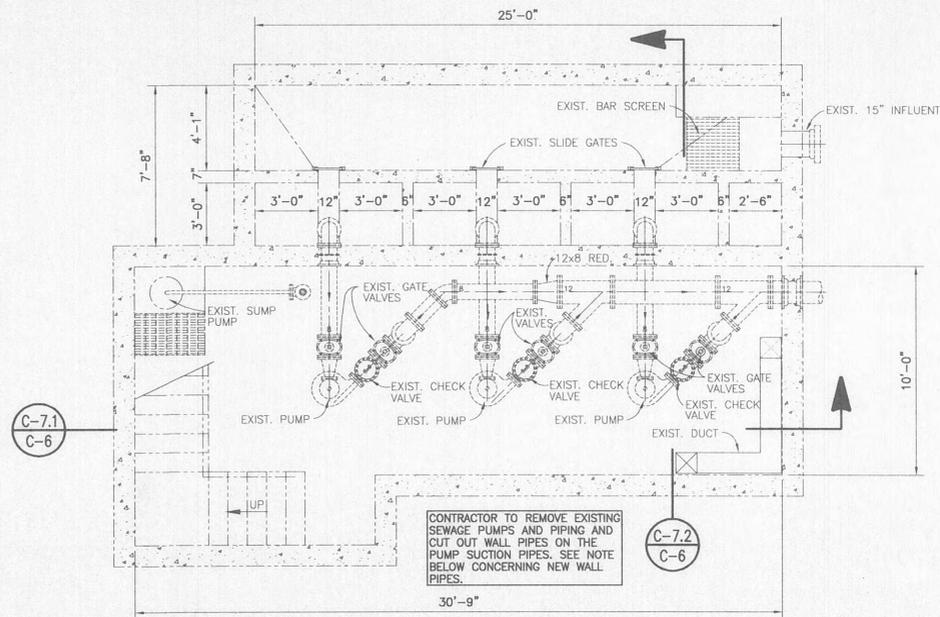


**EXISTING FLOOR PLAN — PUMP LEVEL**  
SCALE: 1/4" = 1'-0"


- CONTRACTOR NOTES:**
1. CONTRACTOR SHALL BE RESPONSIBLE FOR BYPASS PUMPING WHILE REHABILITATING PUMP STATION. THIS INCLUDES ANY REQUIRED CONNECTIONS TO INFLUENT AND DISCHARGE LINES. HUB WILL PROVIDE THE REQUIRED ELECTRICAL SERVICE FOR BYPASS PUMPING.
  2. THE OWNER SHALL HAVE FIRST SALVAGE RIGHTS TO ALL EXISTING VALVES, PIPING AND EQUIPMENT. IF THE OWNER REJECTS SALVAGED MATERIALS, THE CONTRACTOR SHALL PROVIDE FINAL DISPOSAL OF ALL ITEMS.
  3. CONTRACTOR TO CLEAN AND PAINT PIPING AND WALLS. WALLS INCLUDE ENTRANCE LEVEL ELECTRICAL AREA AND PUMP LEVEL. PUMP AND PIPING AREA.

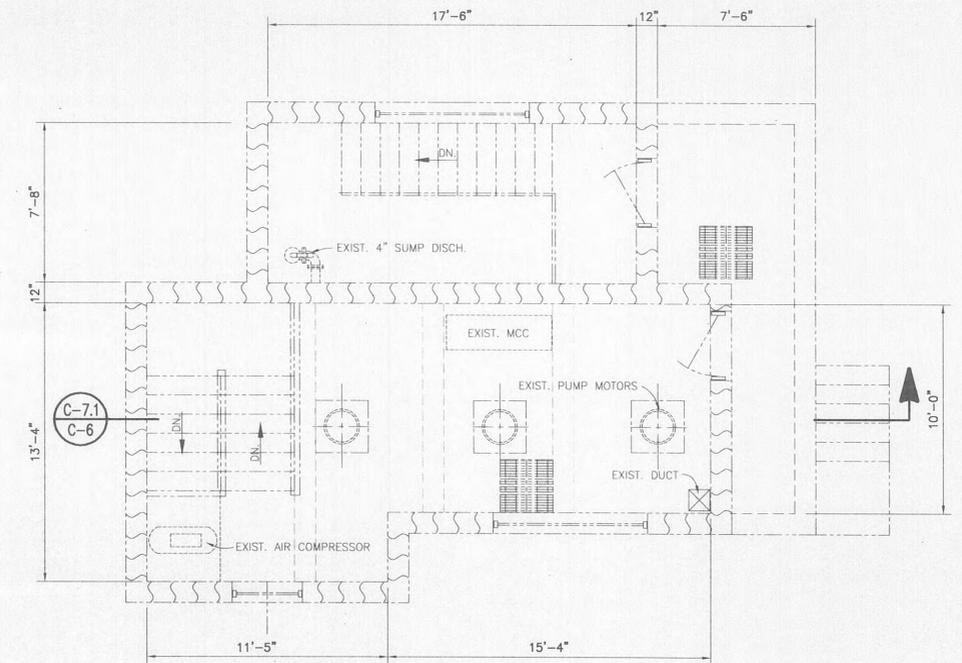

**EXISTING FLOOR PLAN — ENTRANCE LEVEL**  
SCALE: 1/4" = 1'-0"

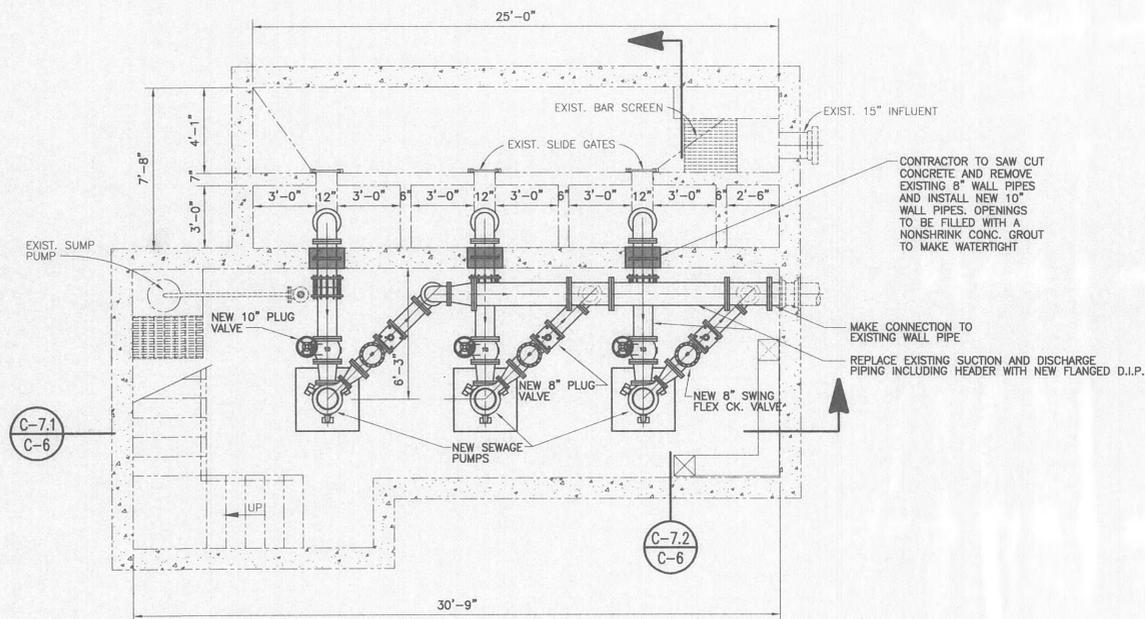

**MODIFIED FLOOR PLAN — PUMP LEVEL**  
SCALE: 1/4" = 1'-0"

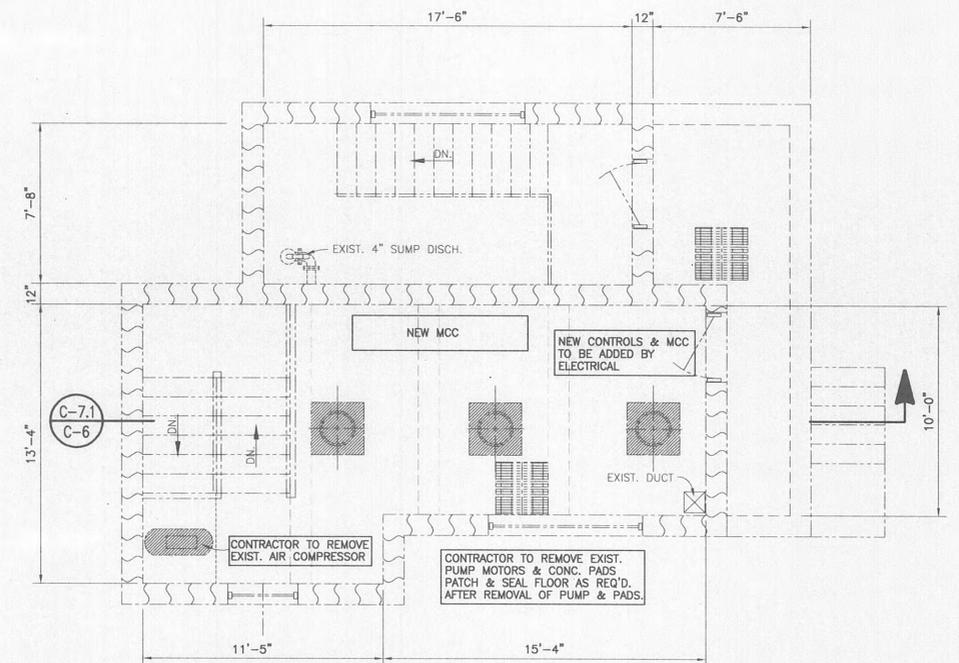


**MODIFIED FLOOR PLAN — ENTRANCE LEVEL**  
SCALE: 1/4" = 1'-0"

FILE NAME: 7601-30-06

GRW PROJECT NO. 7601-30 CONTRACT NO. S02-03  
**EXISTING WEBB SEWAGE PUMP STATION**  
 PLAN VIEWS  
 HARRIMAN UTILITY BOARD  
 HARRIMAN, TENNESSEE


THIS DOCUMENT IS THE PROPERTY OF GRW ELROD DUNSON, INC. AND SHALL NOT BE REPRODUCED IN WHOLE OR IN PART OR USED FOR CONSTRUCTION OF OTHER THAN THIS SPECIFIC PROJECT WITHOUT WRITTEN PERMISSION OF GRW ELROD DUNSON, INC.

NO.	DESCRIPTION	DATE	BY

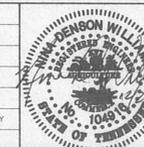


**GRW**  
**GRW Elrod Dunson, Inc.**  
 Engineers, Architects, Planners  
 LEXINGTON LOUISVILLE INDIANAPOLIS  
 NASHVILLE KNOXVILLE


DESIGNED: RGT/NDW	DATE: NOVEMBER, 2002
DRAWN: DGR	SCALE: AS NOTED
REVIEWED: NDW	SHEET NO. C-6
APPROVED: RGT	

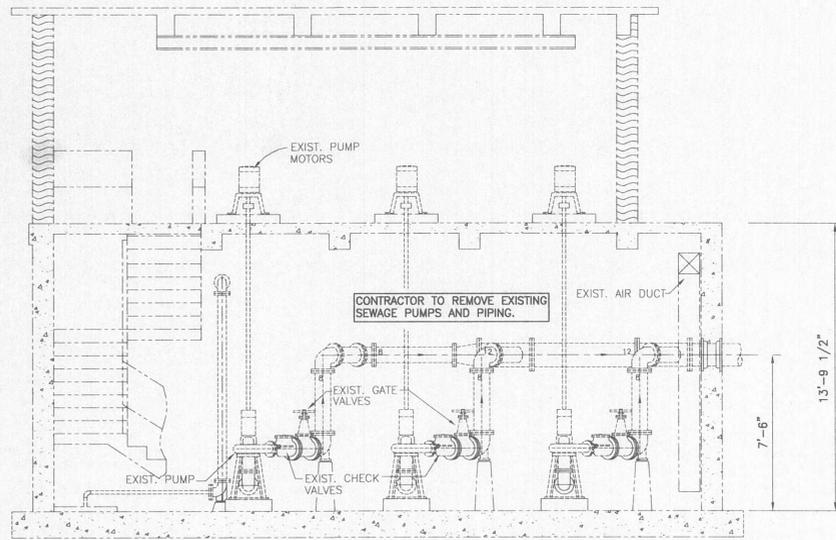


EXISTING CONDITIONS—SECTION C-7.2  
SCALE: 1/4" = 1'-0"  
C-6

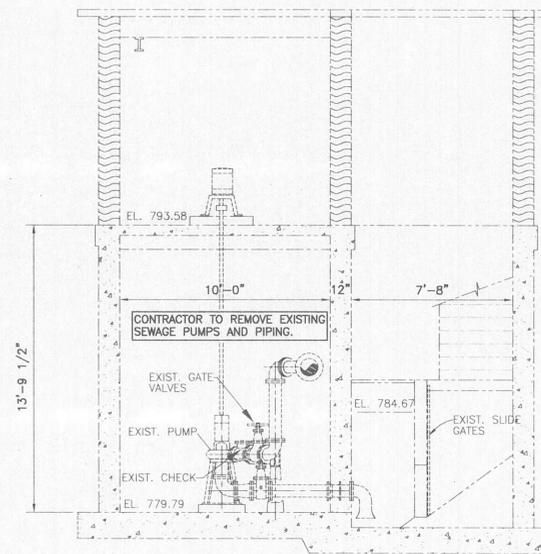

EXISTING CONDITIONS—SECTION C-7.1  
SCALE: 1/4" = 1'-0"  
C-6

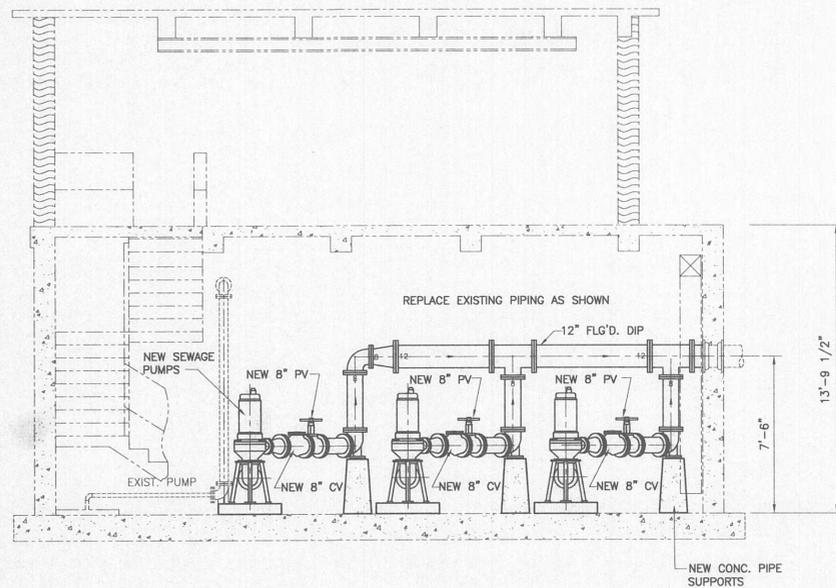

MODIFIED CONDITIONS—SECTION C-7.2  
SCALE: 1/4" = 1'-0"  
C-6

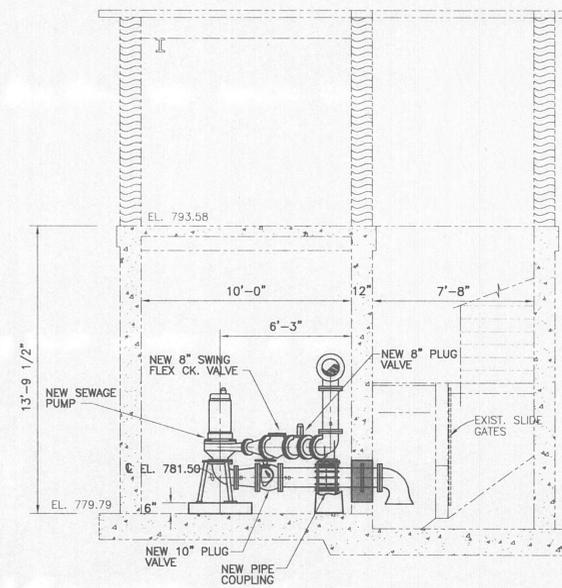


MODIFIED CONDITIONS—SECTION C-7.1  
SCALE: 1/4" = 1'-0"  
C-6

GRW PROJECT NO. 7601-30 CONTRACT NO. S02-03

EXISTING WEBB SEWAGE PUMP STATION  
SECTIONS  
HARRIMAN UTILITY BOARD  
HARRIMAN, TENNESSEE

THIS DOCUMENT IS THE PROPERTY OF GRW ELROD DUNSON, INC. AND SHALL NOT BE REPRODUCED IN WHOLE OR IN PART OR USED FOR CONSTRUCTION OF OTHER THAN THIS SPECIFIC PROJECT WITHOUT WRITTEN PERMISSION OF GRW ELROD DUNSON, INC.

NO.	DESCRIPTION	DATE	BY

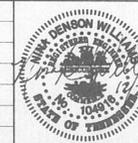

**GRW Elrod Dunson, Inc.**  
Engineers, Architects, Planners  
LEXINGTON LOUISVILLE INDIANAPOLIS  
NASHVILLE KNOXVILLE

DESIGNED: RGT/NDW	DATE: NOVEMBER, 2002
DRAWN: DGR	SCALE: AS NOTED
REVIEWED: NDW	SHEET NO. C-7
APPROVED: RGT	