

WOLFE BRANCH UTILITY DISTRICT

MORGAN & ROANE COUNTIES, TENNESSEE

WATERWORKS PROJECT

CONTRACT NO. 2

50,000 GALLON STORAGE RESERVOIR

*CHANGED TO 100,000
change order #1*

INDEX OF DRAWINGS

DWG. NO.

COVER SHEET	390-2-1
RESERVOIR LOCATION PLAN	390-2-2
50,000 GALLON STORAGE RESERVOIR	390-2-3
SITE PLAN-50,000 GALLON STORAGE RESERVOIR	390-2-4


BOARD OF COMMISSIONERS

FRED NEWCOMB, CHAIRMAN
PAUL SCARBROUGH, SECRETARY
HOLLIS EBLE, COMMISSIONER

DONALD PAINTER, MANAGER


U.S. DEPARTMENT OF AGRICULTURE
FARMERS HOME ADMINISTRATION

WILLIAM PATTERSON-COUNTY SUPERVISOR

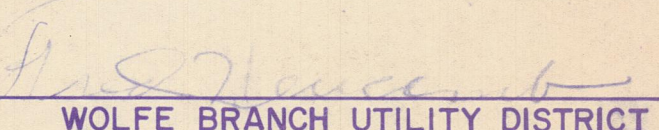
APPROVED 
WOLFE BRANCH UTILITY DISTRICT

PREPARED BY
BOUQUARD ENGINEERING CO., INC.

CHATTANOOGA, TENNESSEE
APRIL 1976

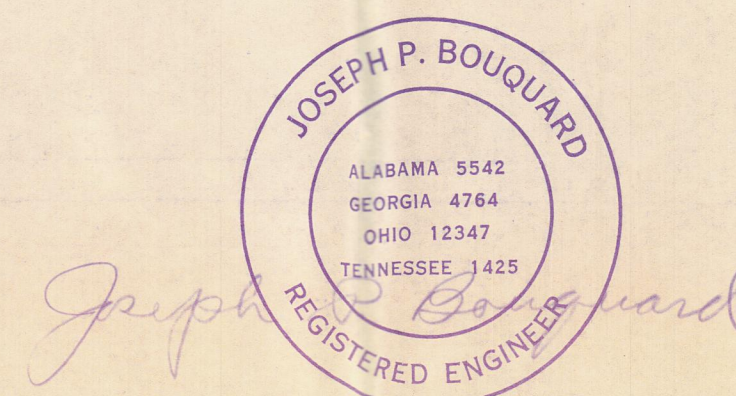

SET NO. _____


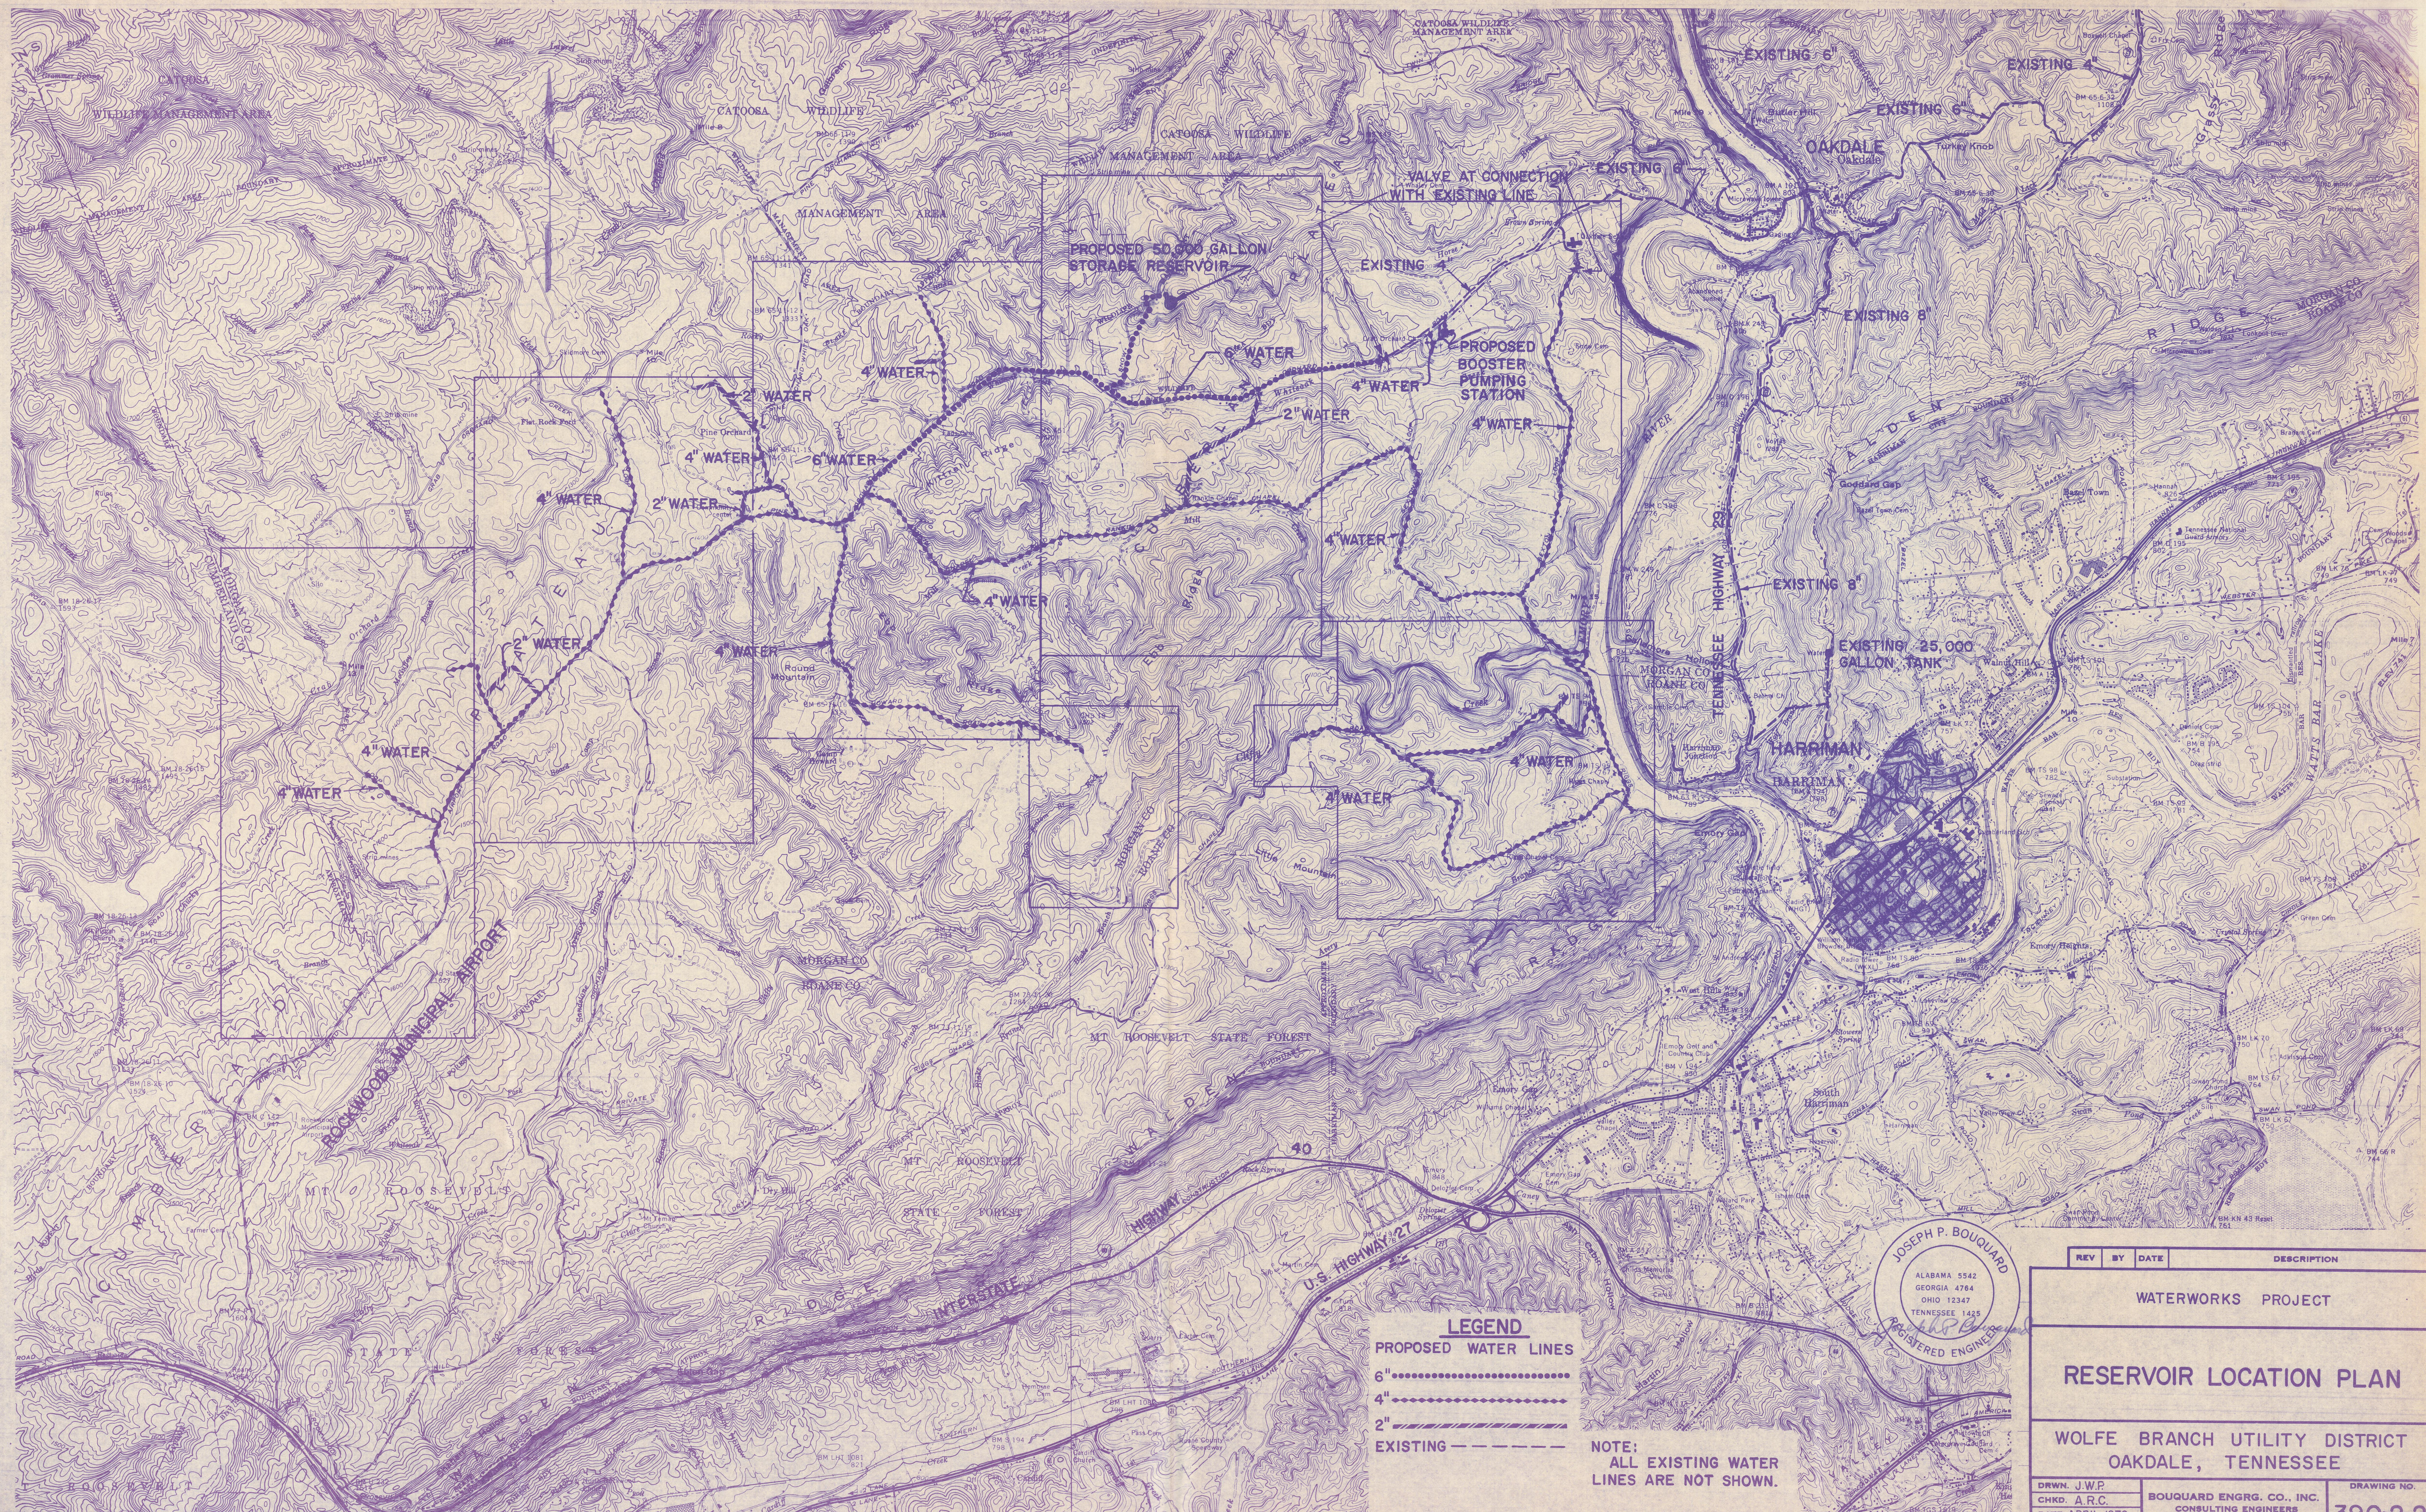


LEGEND
PROPOSED WATER LINES
6"
4"
2"
EXISTING ———


NOTE:
ALL EXISTING WATER
LINES ARE NOT SHOWN.

JOSEPH P. BOUQUARD
ALABAMA 5542
GEORGIA 4764
OHIO 12347
TENNESSEE 1425
REGISTERED ENGINEER


REV	BY	DATE	DESCRIPTION
WATERWORKS PROJECT			
RESERVOIR LOCATION PLAN			
WOLFE BRANCH UTILITY DISTRICT OAKDALE, TENNESSEE			
DRWN. J.W.P. CHKD. A.R.C. DATE APRIL 1976 SCALE: 1"=2000'	BOUQUARD ENGRG. CO., INC. CONSULTING ENGINEERS CHATTANOOGA, TENNESSEE		DRAWING NO. 390-2-2

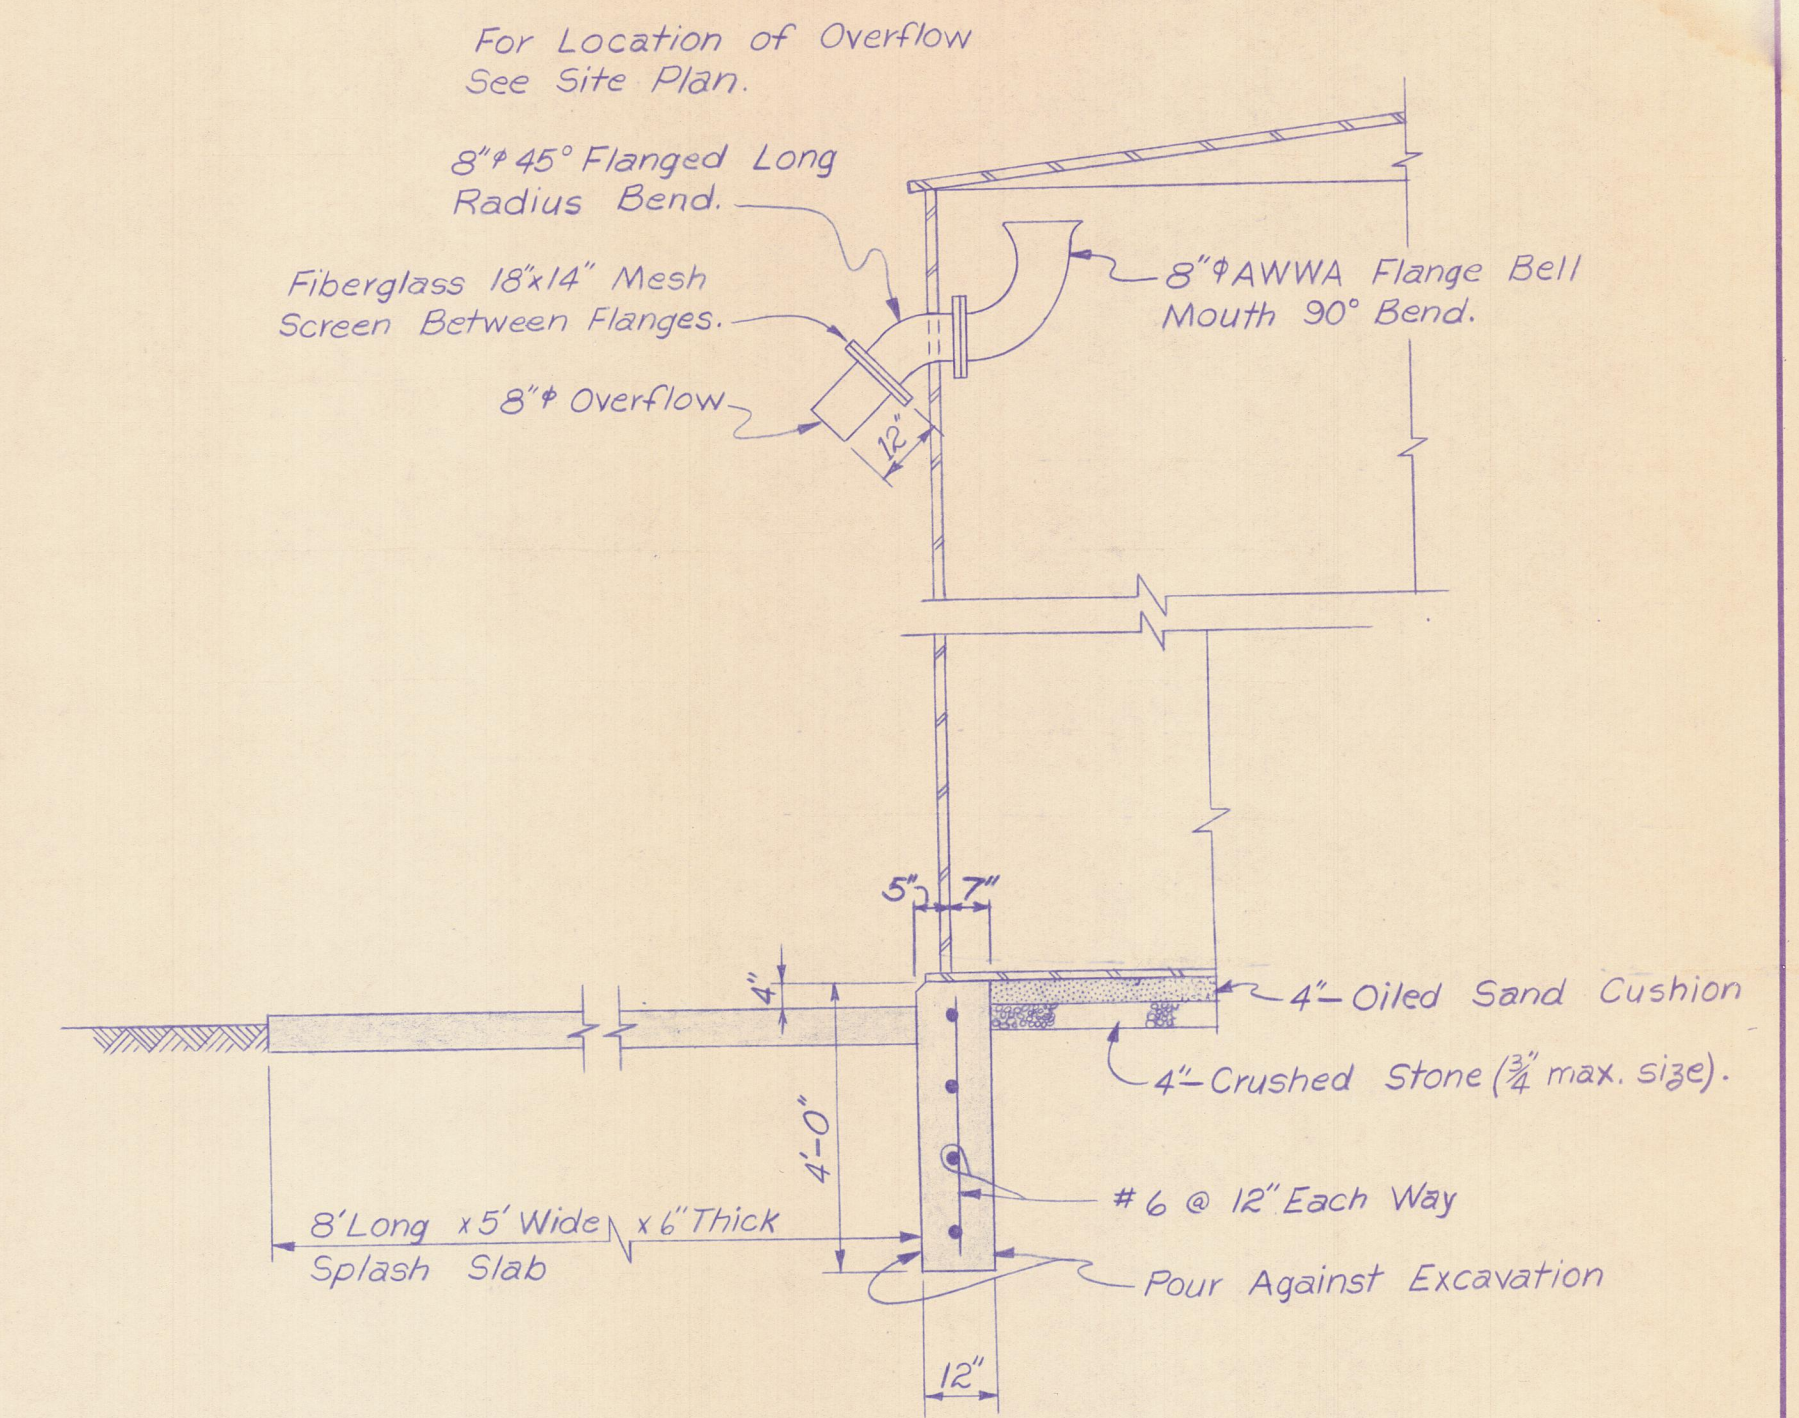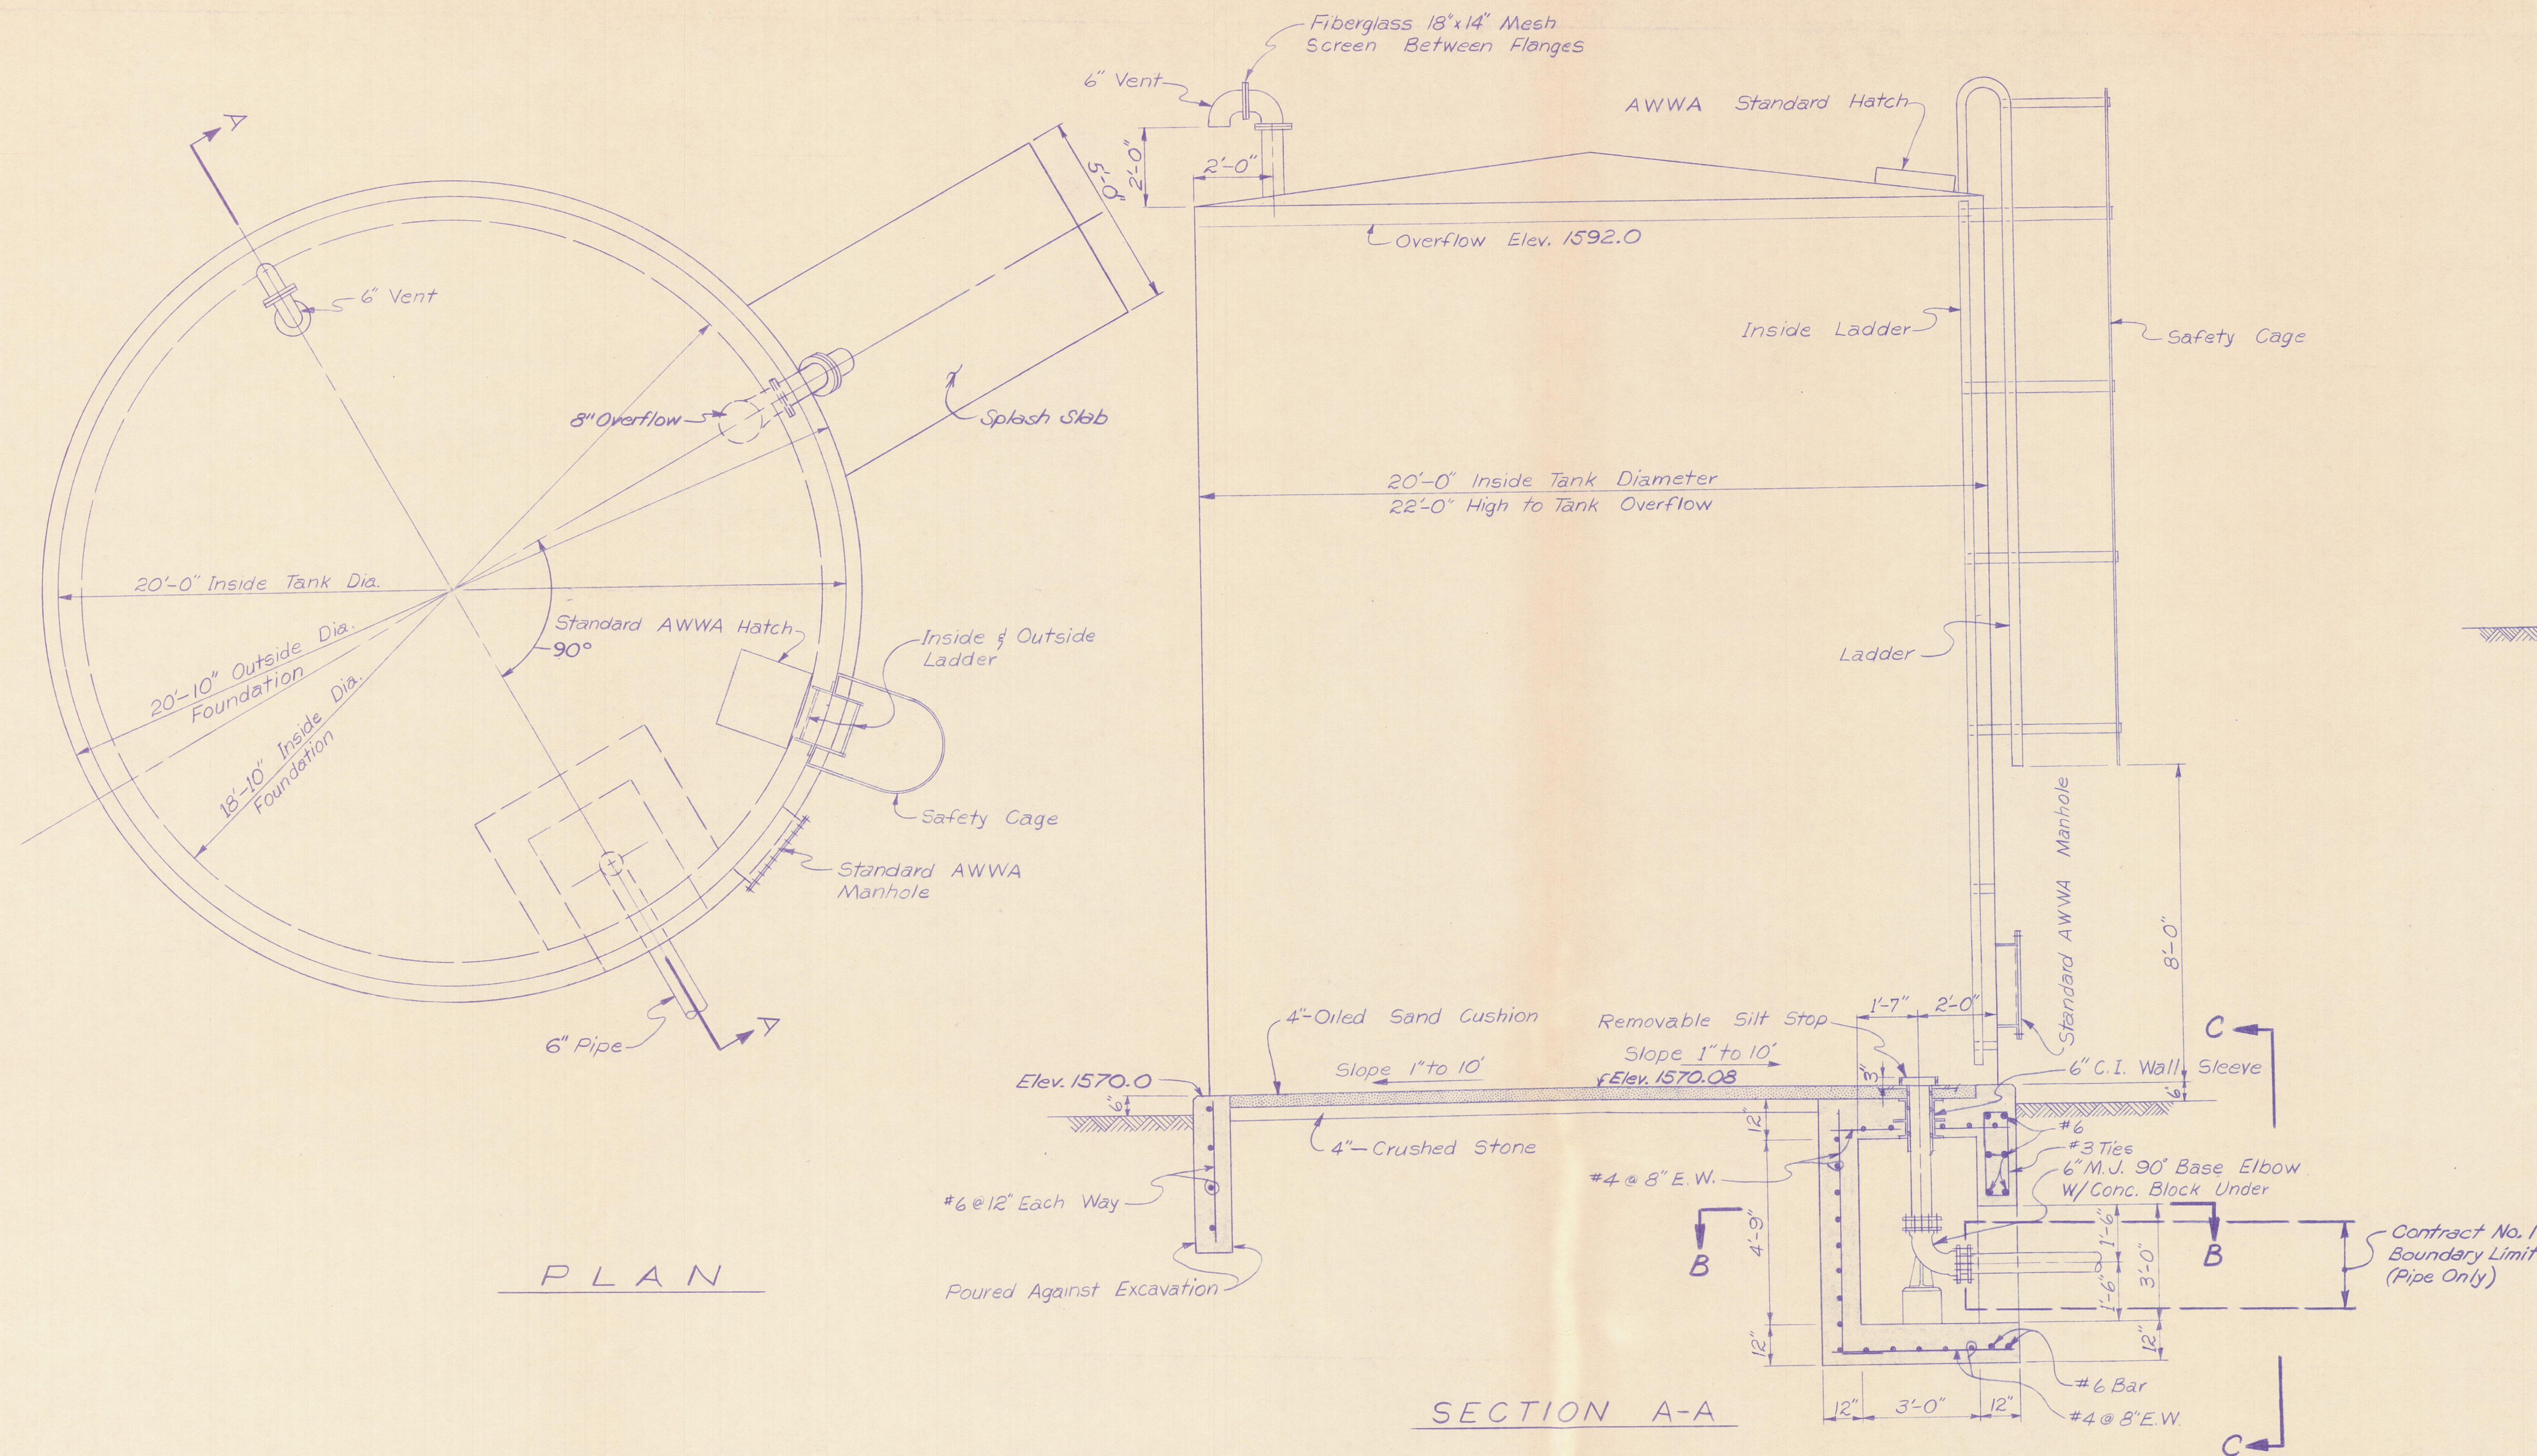

RINGWALL & OVERFLOW DETAIL

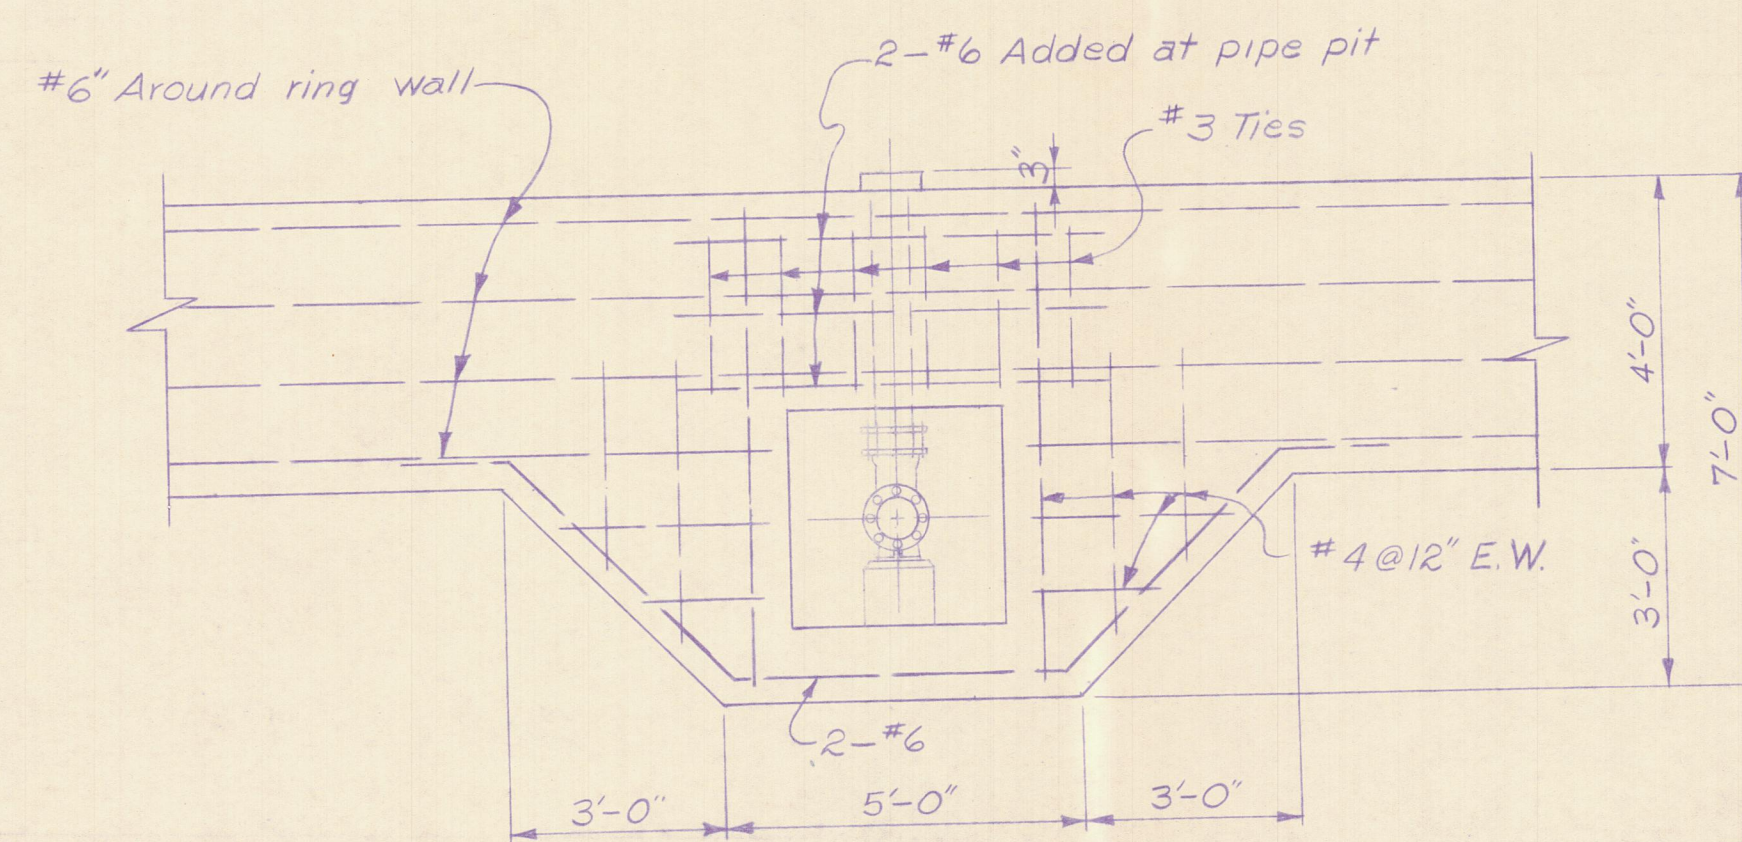


SECTIONAL ELEVATION C-C

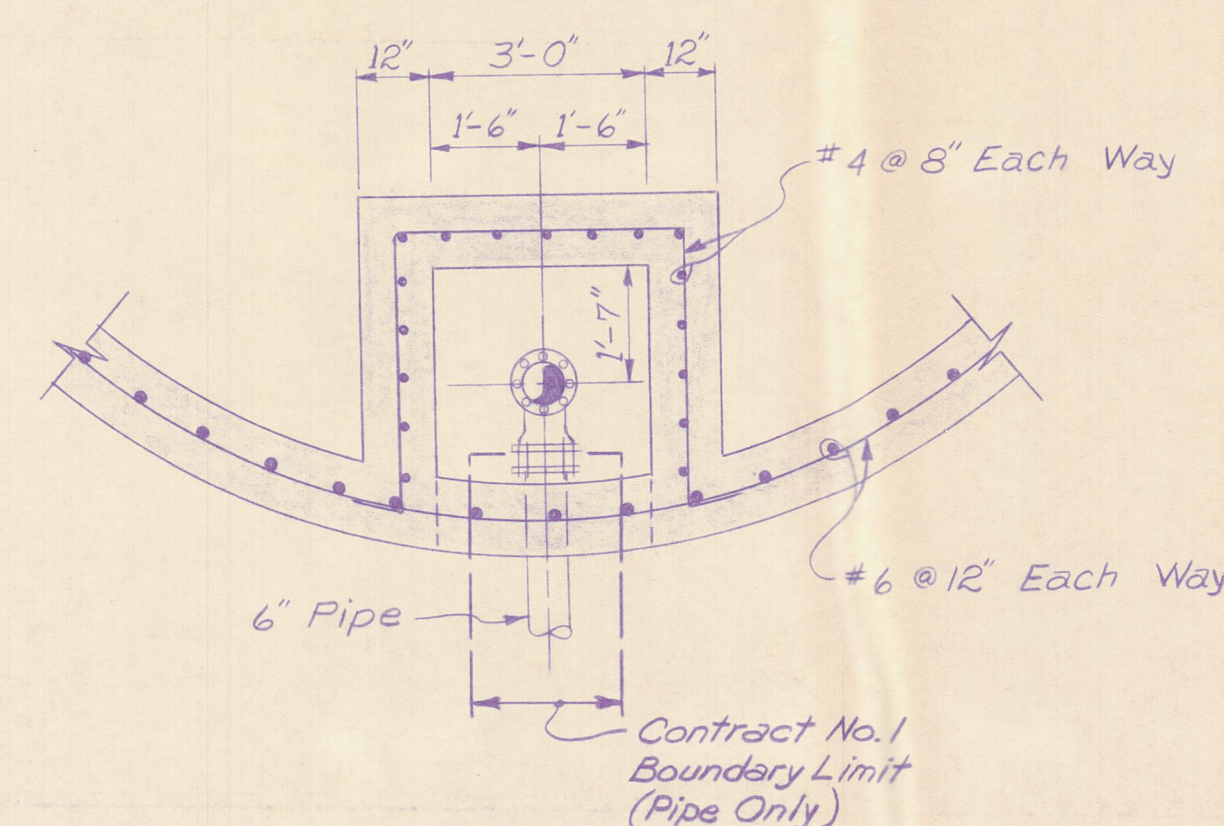


SECTION B-B



50,000 GALLON STORAGE RESERVOIR - 1 REQUIRED

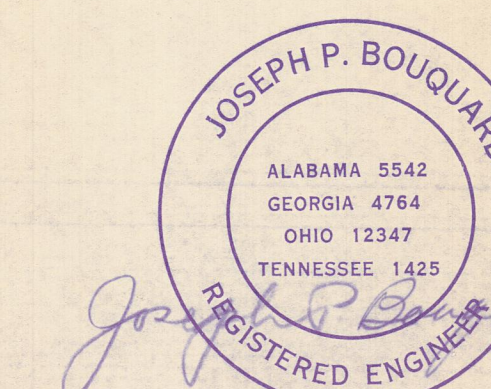

REV	BY	DATE	DESCRIPTION
WATERWORKS PROJECT			
50,000 GALLON STORAGE RESERVOIR			
WOLFE BRANCH UTILITY DISTRICT OAKDALE, TENNESSEE			
DRWN. GWP		DRAWING NO.	
CHKD. A.R.C.		BOUQUARD ENGRG. CO., INC.	
DATE APRIL 1976		CONSULTING ENGINEERS	
SCALE 3/8" = 1'-0"		CHATTANOOGA, TENNESSEE	
		390-2-3	

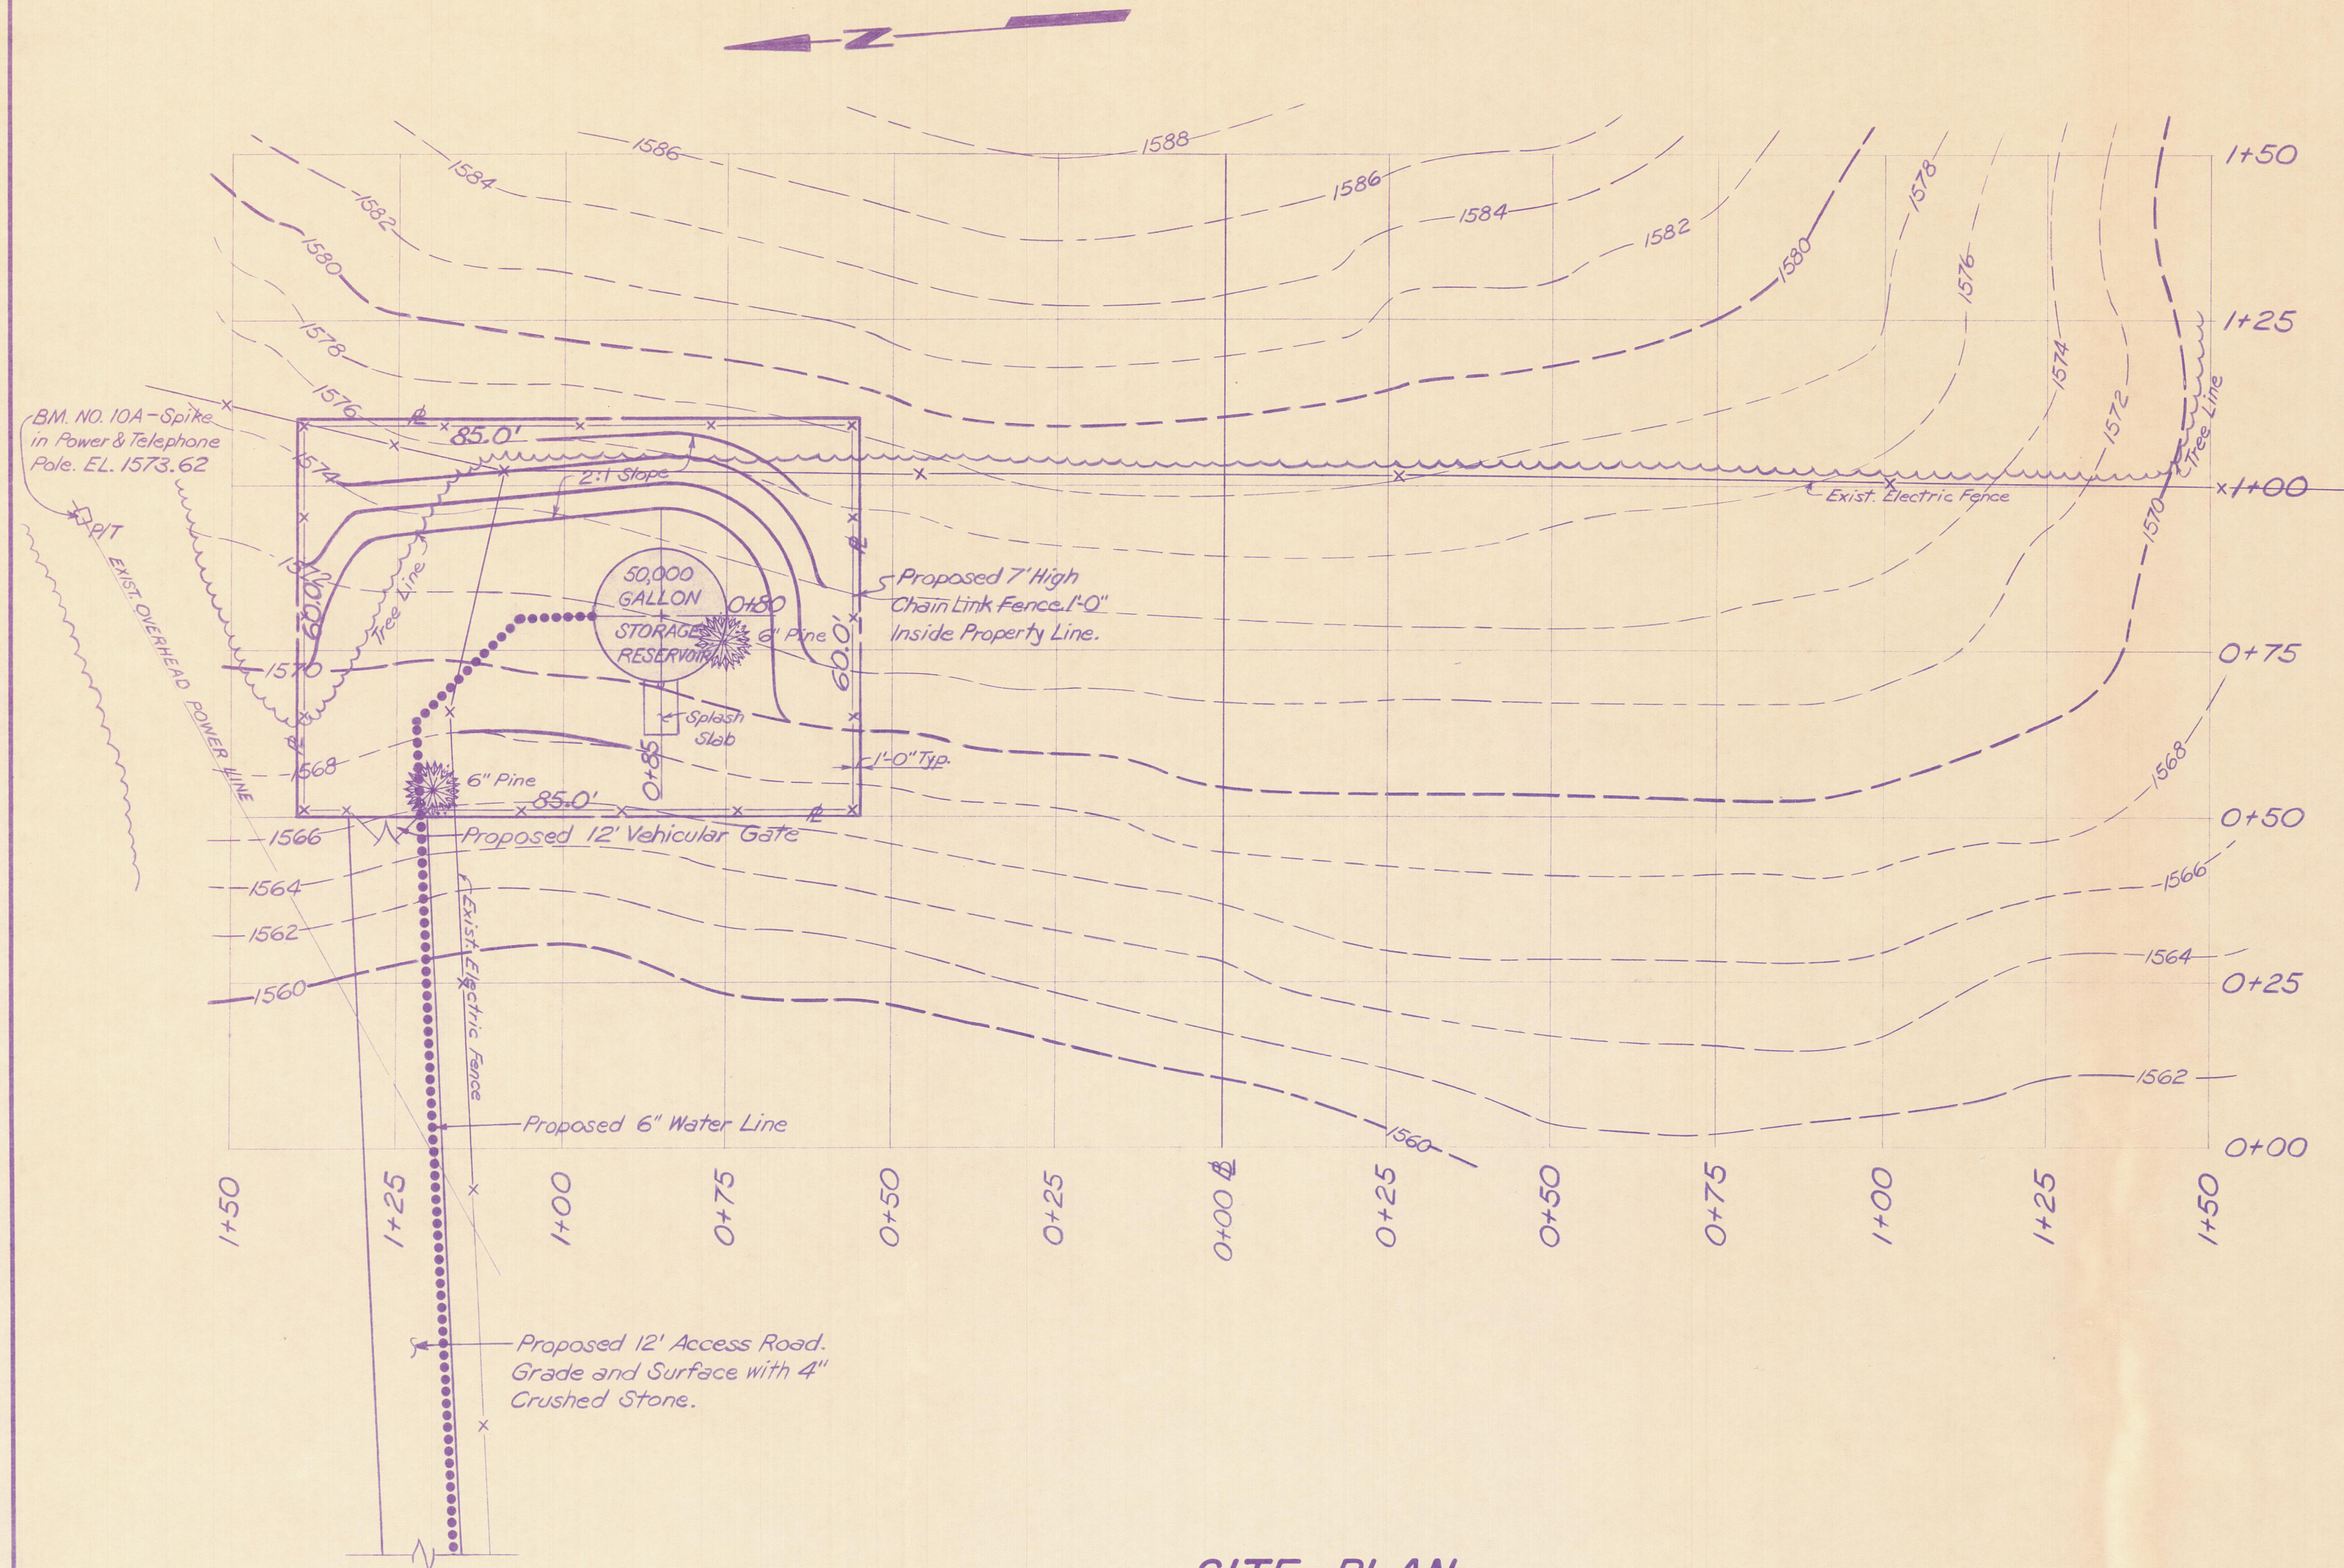

SITE PLAN
SCALE: 1"=20'

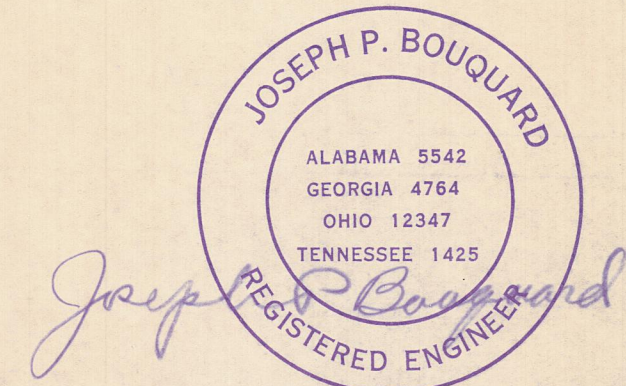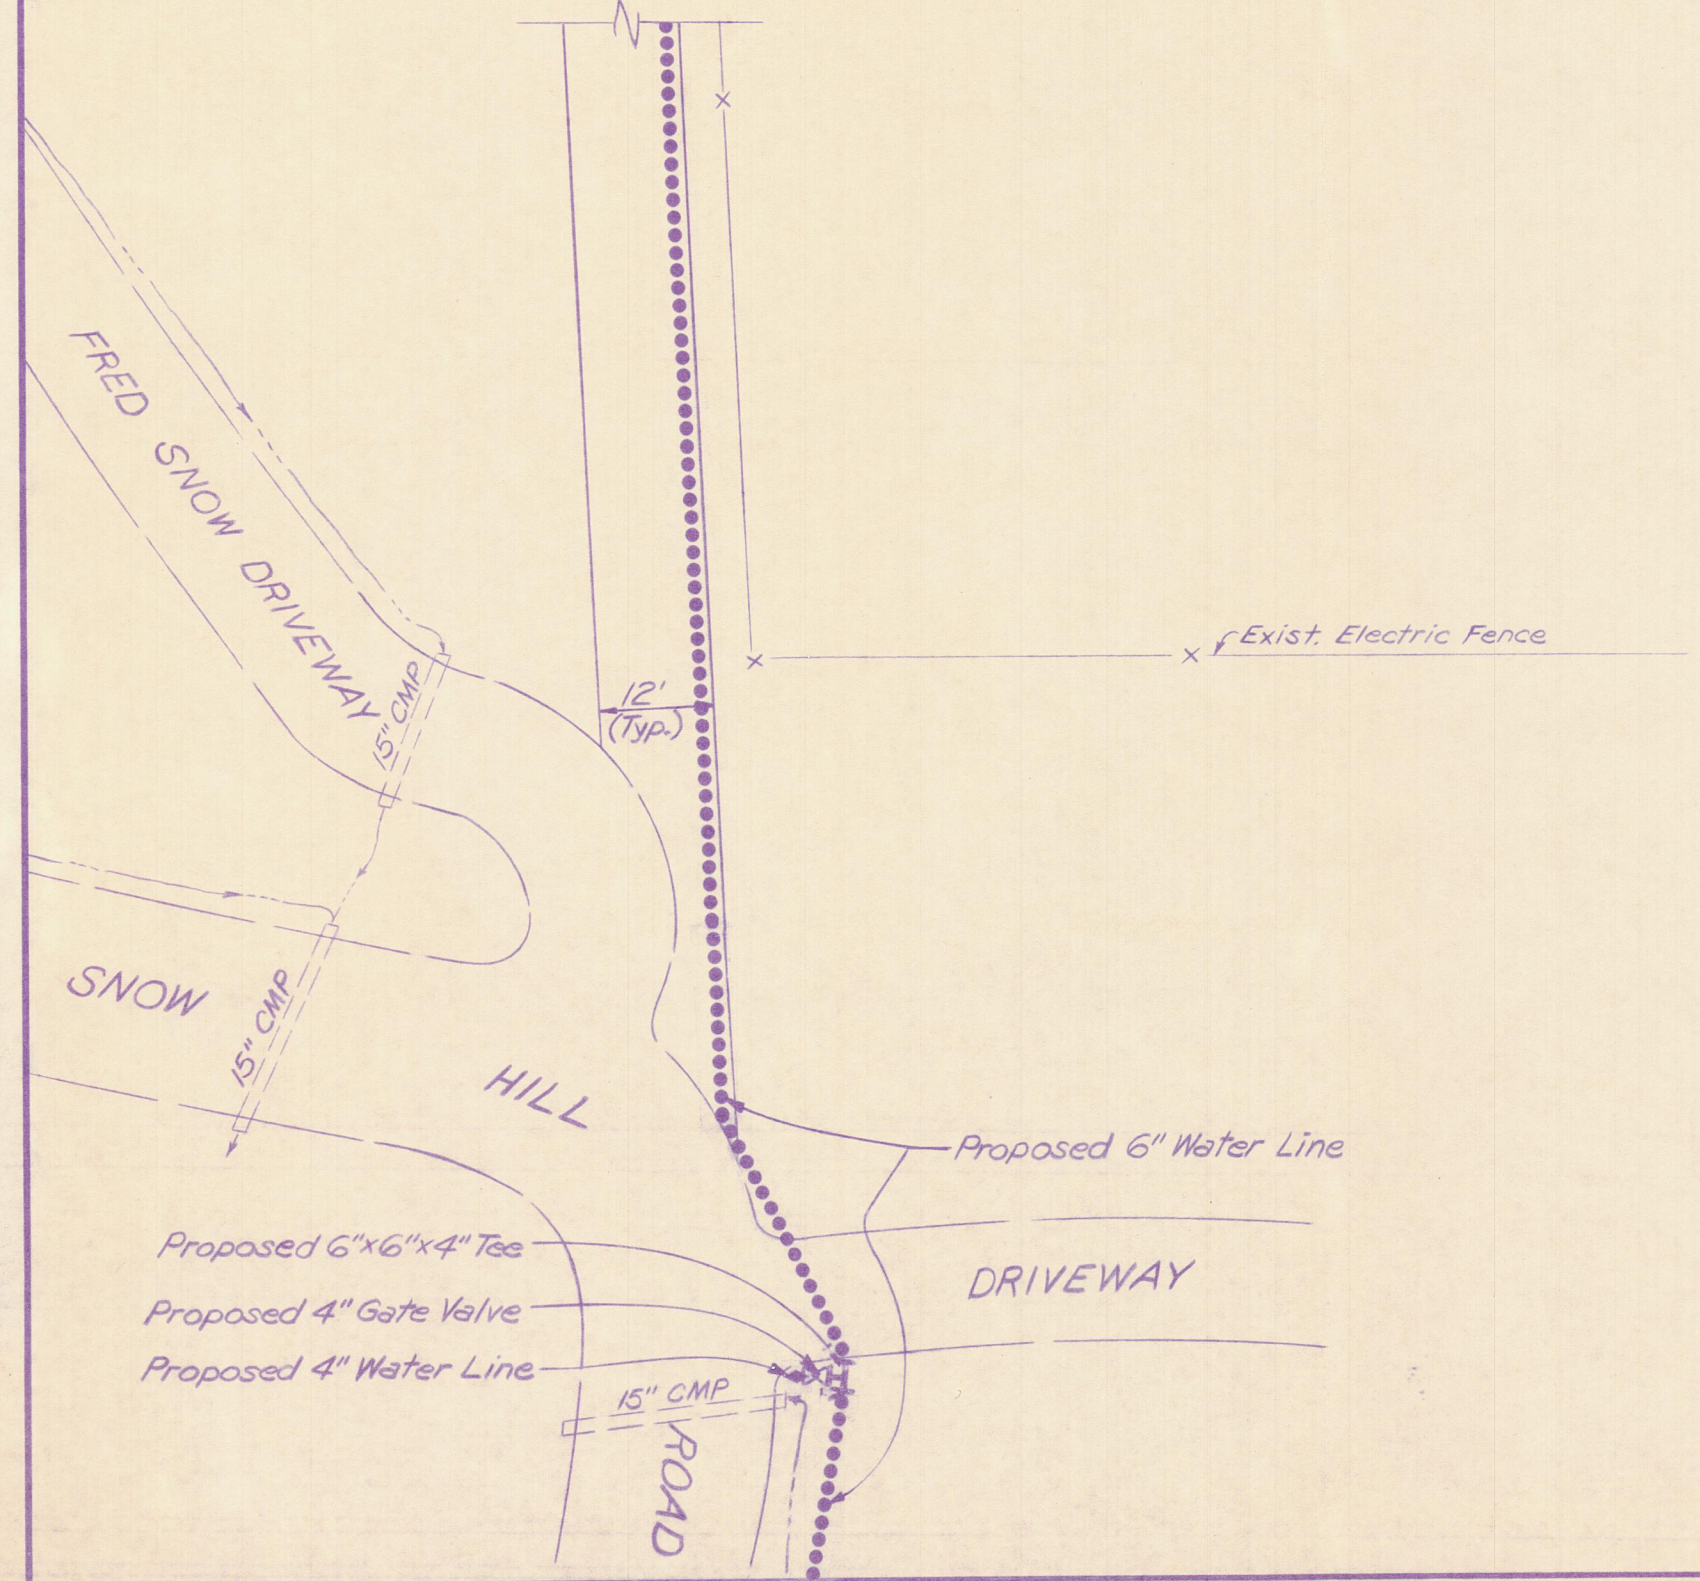

REF: F.B. #65, PG. 27

REV	BY	DATE	DESCRIPTION
WATERWORKS PROJECT			
SITE PLAN 50,000 GALLON STORAGE RESERVOIR			
WOLFE BRANCH UTILITY DISTRICT OAKDALE, TENNESSEE			
DRWN. G.L.M.		DRAWING NO.	
CHKD. A.R.C.		BOUQUARD ENGRG. CO., INC.	
DATE APRIL, 1976		CONSULTING ENGINEERS	
SCALE AS SHOWN		CHATTANOOGA, TENNESSEE	
		390-2-4	